## INTERIOR ELEVATION NOTES 1 NEW TOILET (2) NEW GRAB BARS (3) NEW SINK NEW COUNTERTOP AND BACKSPLASH **NEW URINAL NEW MIRROR** NEW SOAP DISPENSER NEW PAPER TOWEL DISPENSER/DISPOSAL NEW TOILET PAPER DISPENSER (10) NEW SANITARY NAPKIN DISPOSAL NEW TOILET PARTITION (12) APPLIANCES PROVIDED BY OWNER (13) ( P.LAM. TALL CABINET. SECURE TO WALL. NEW FLOOR DRAIN NEW MODULAR WALK-IN COOLER. PROVIDE METAL ENCLOSURE PANELS BETWEEN COOLER AND EXISTING WALL (TYP. ON EACH SIDE).

ARCHITECTS . ENGINEERS . CONSULTANTS

Corporate Headquarters 45650 Grand River Ave. Novi, Michigan 48374 Ph: (248)349-4500 • Fax: (248)349-1429

> Novi • Wyandotte • Muskegon Lansing • Gaylord • Sault Ste. Marie Williamsport, PA • Tampa, FL www.sidockgroup.com

Brownstown Township

**Brownstown Community** Center Rennovation & Addition

Issued For

100% CD

AM/KN/NC


KN


21311 Telegraph Rd.

Brownstown, MI Seal:


DESIGN DEVELOPMENT 11/05/2024 PROGRESS SET 90% OWNER REVIEW 12/09/2024 12/20/2024 01/07/2025 01/21/2025 ADDENDUM 2 Checked: Approved: Sheet Title: **ENLARGED PLANS** 


24361.A

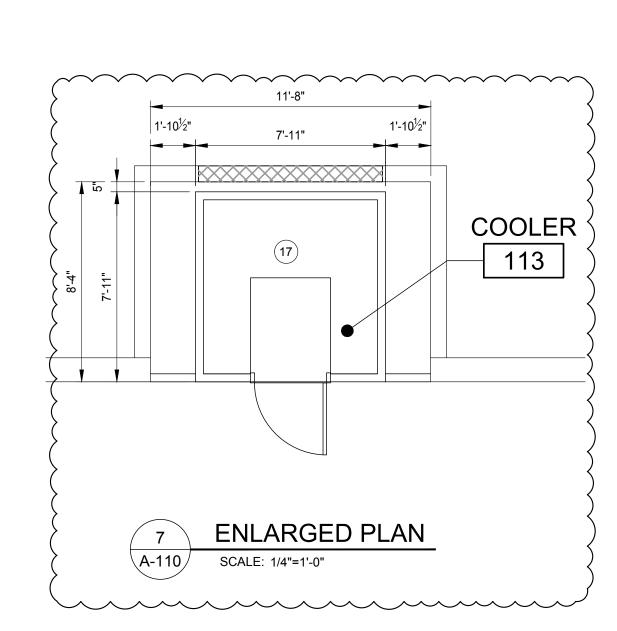


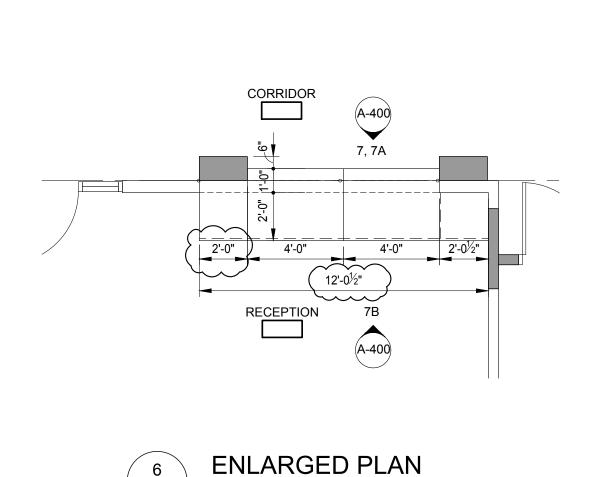



SCALE: 1/4"=1'-0"

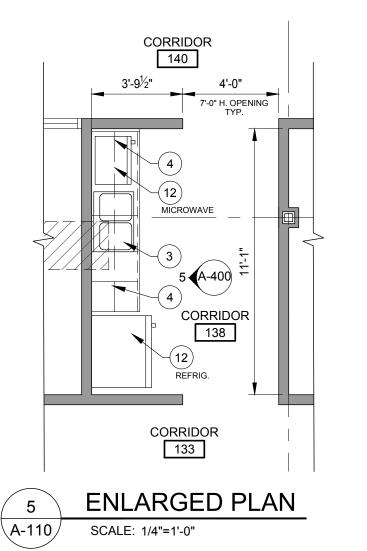

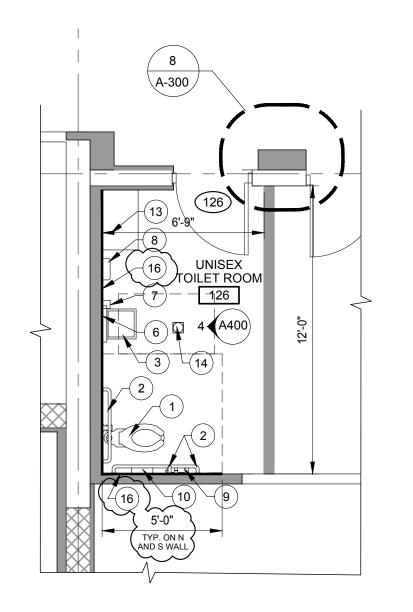


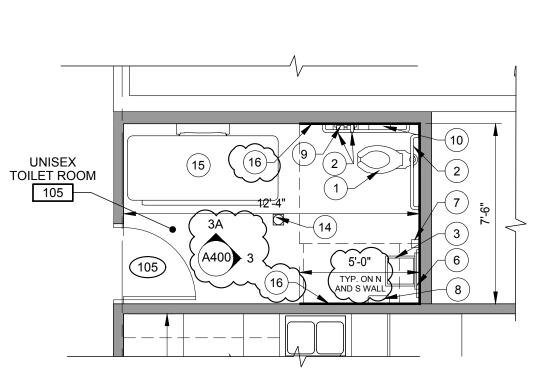

 

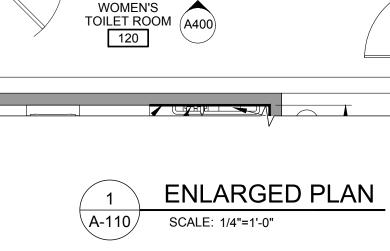

MEN'S TOI<u>LET RO</u>OM

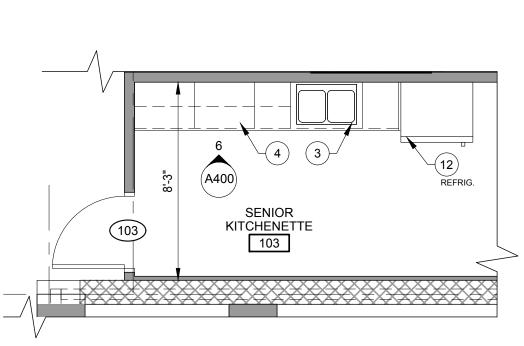

ONE (1) MODULAR, SELF-CONTAINED INDOOR WALK-IN COOLER

EACH PANEL SHALL CONSIST OF INTERIOR AND EXTERIOR

BASIS OF DESIGN: ARTIC INDUSTRIES MODEL NO. BL88-CF-SC

METAL SKIN, A 4" EXTRUDED POLYSTYRENE INSULATION CORE

22 GAUGE SMOOTH GALVANIZED STEEL

(R-28 OR GREATER), AND BE EQUIPPED WITH CAM-ACTION

- WALL/CEILING: 26 GAUGE MILL EMBOSSED ACRYLUME

WALL AND CEILING PANELS: R-28 OR GREATER; VAPOR

INSTALLATION PRIOR TO INSTALLATION OF COOLER.

- SIZE: 34" x 78" DOOR WITH INTERIOR/EXTERIOR 24" H.

5 YEAR COMPRESSOR WARRANTY, 1 YEAR PARTS AND LABOR,

 REFRIGERATION UNIT TO BE TOP MOUNTED. REQUIRES TWO FEET CLEARANCE ABOVE UNIT. EXISTING ACOUSTICAL CEILING

• ELECTRICAL DETAILS: REFER TO ELECTRICAL DRAWINGS.

 SPRINKLER HEAD - PROVIDE HEAD IN THE W.I.C. AND ABOVE; MODIFY EXISTING SPRINKLER HEAD AS REQUIRED. CUT HOLES FOR SPRINKLER HEADS, PROVIDE STAINLESS STEEL TRIM CAP

- 1/8" THICK ALUMINUM DIAMOND KICK PLATE - KEY LOCK HANDLE, CAM-LIFT SPRING ASSISTED SELF-CLOSING HINGE AND ONE CAM-LIFT HINGE

- 30" W. INTERIOR DTP RAMP FOR 34" DOOR

(9'-8" A.F.F) TO BE REMOVE AS REQUIRED.

PROVIDE (1) ONE 4'-0" LED LIGHT, VAPOR PROOF

 CEILING: 4" THICK, EXTRUDED POLYSTRENE MODULAR PANELS JOINED BY CAM-LOCK DEVICE; GASKETS TO SEAL BETWEEN

TRANSMISSION - LESS THAN 1 PERM AND MUST MEET UL 5 FLAME SPREAD RATING WITH AVERAGE SMOKE RATING LESS

CONTRACTOR TO VERIFY EXISTING FLOOR IS LEVEL PRIOR TO

WALK-IN COOLER SPECIFICATIONS

INTERIOR/EXTERIOR FINISH:

THAN 165 (UL 723 TEST)

FLOOR W/INTERIOR RAMP:

- DOOR CLOSER

DIAL THERMOSTAT

AND SEAL HOLES

R448/449 REFRIGERANT

PROVIDE INSIDE SAFETY RELEASE

15 YEAR PANEL WARRANTY

- R-28 RATING OR GREATER

- PREFABRICATED FLOOR 4" H. PANELS

LOCKING DEVICE.

• SIZE: 7'-11" x 7'-11" x 7'-8 1/2" H.

**ENLARGED PLAN** SCALE: 1/4"=1'-0"



