


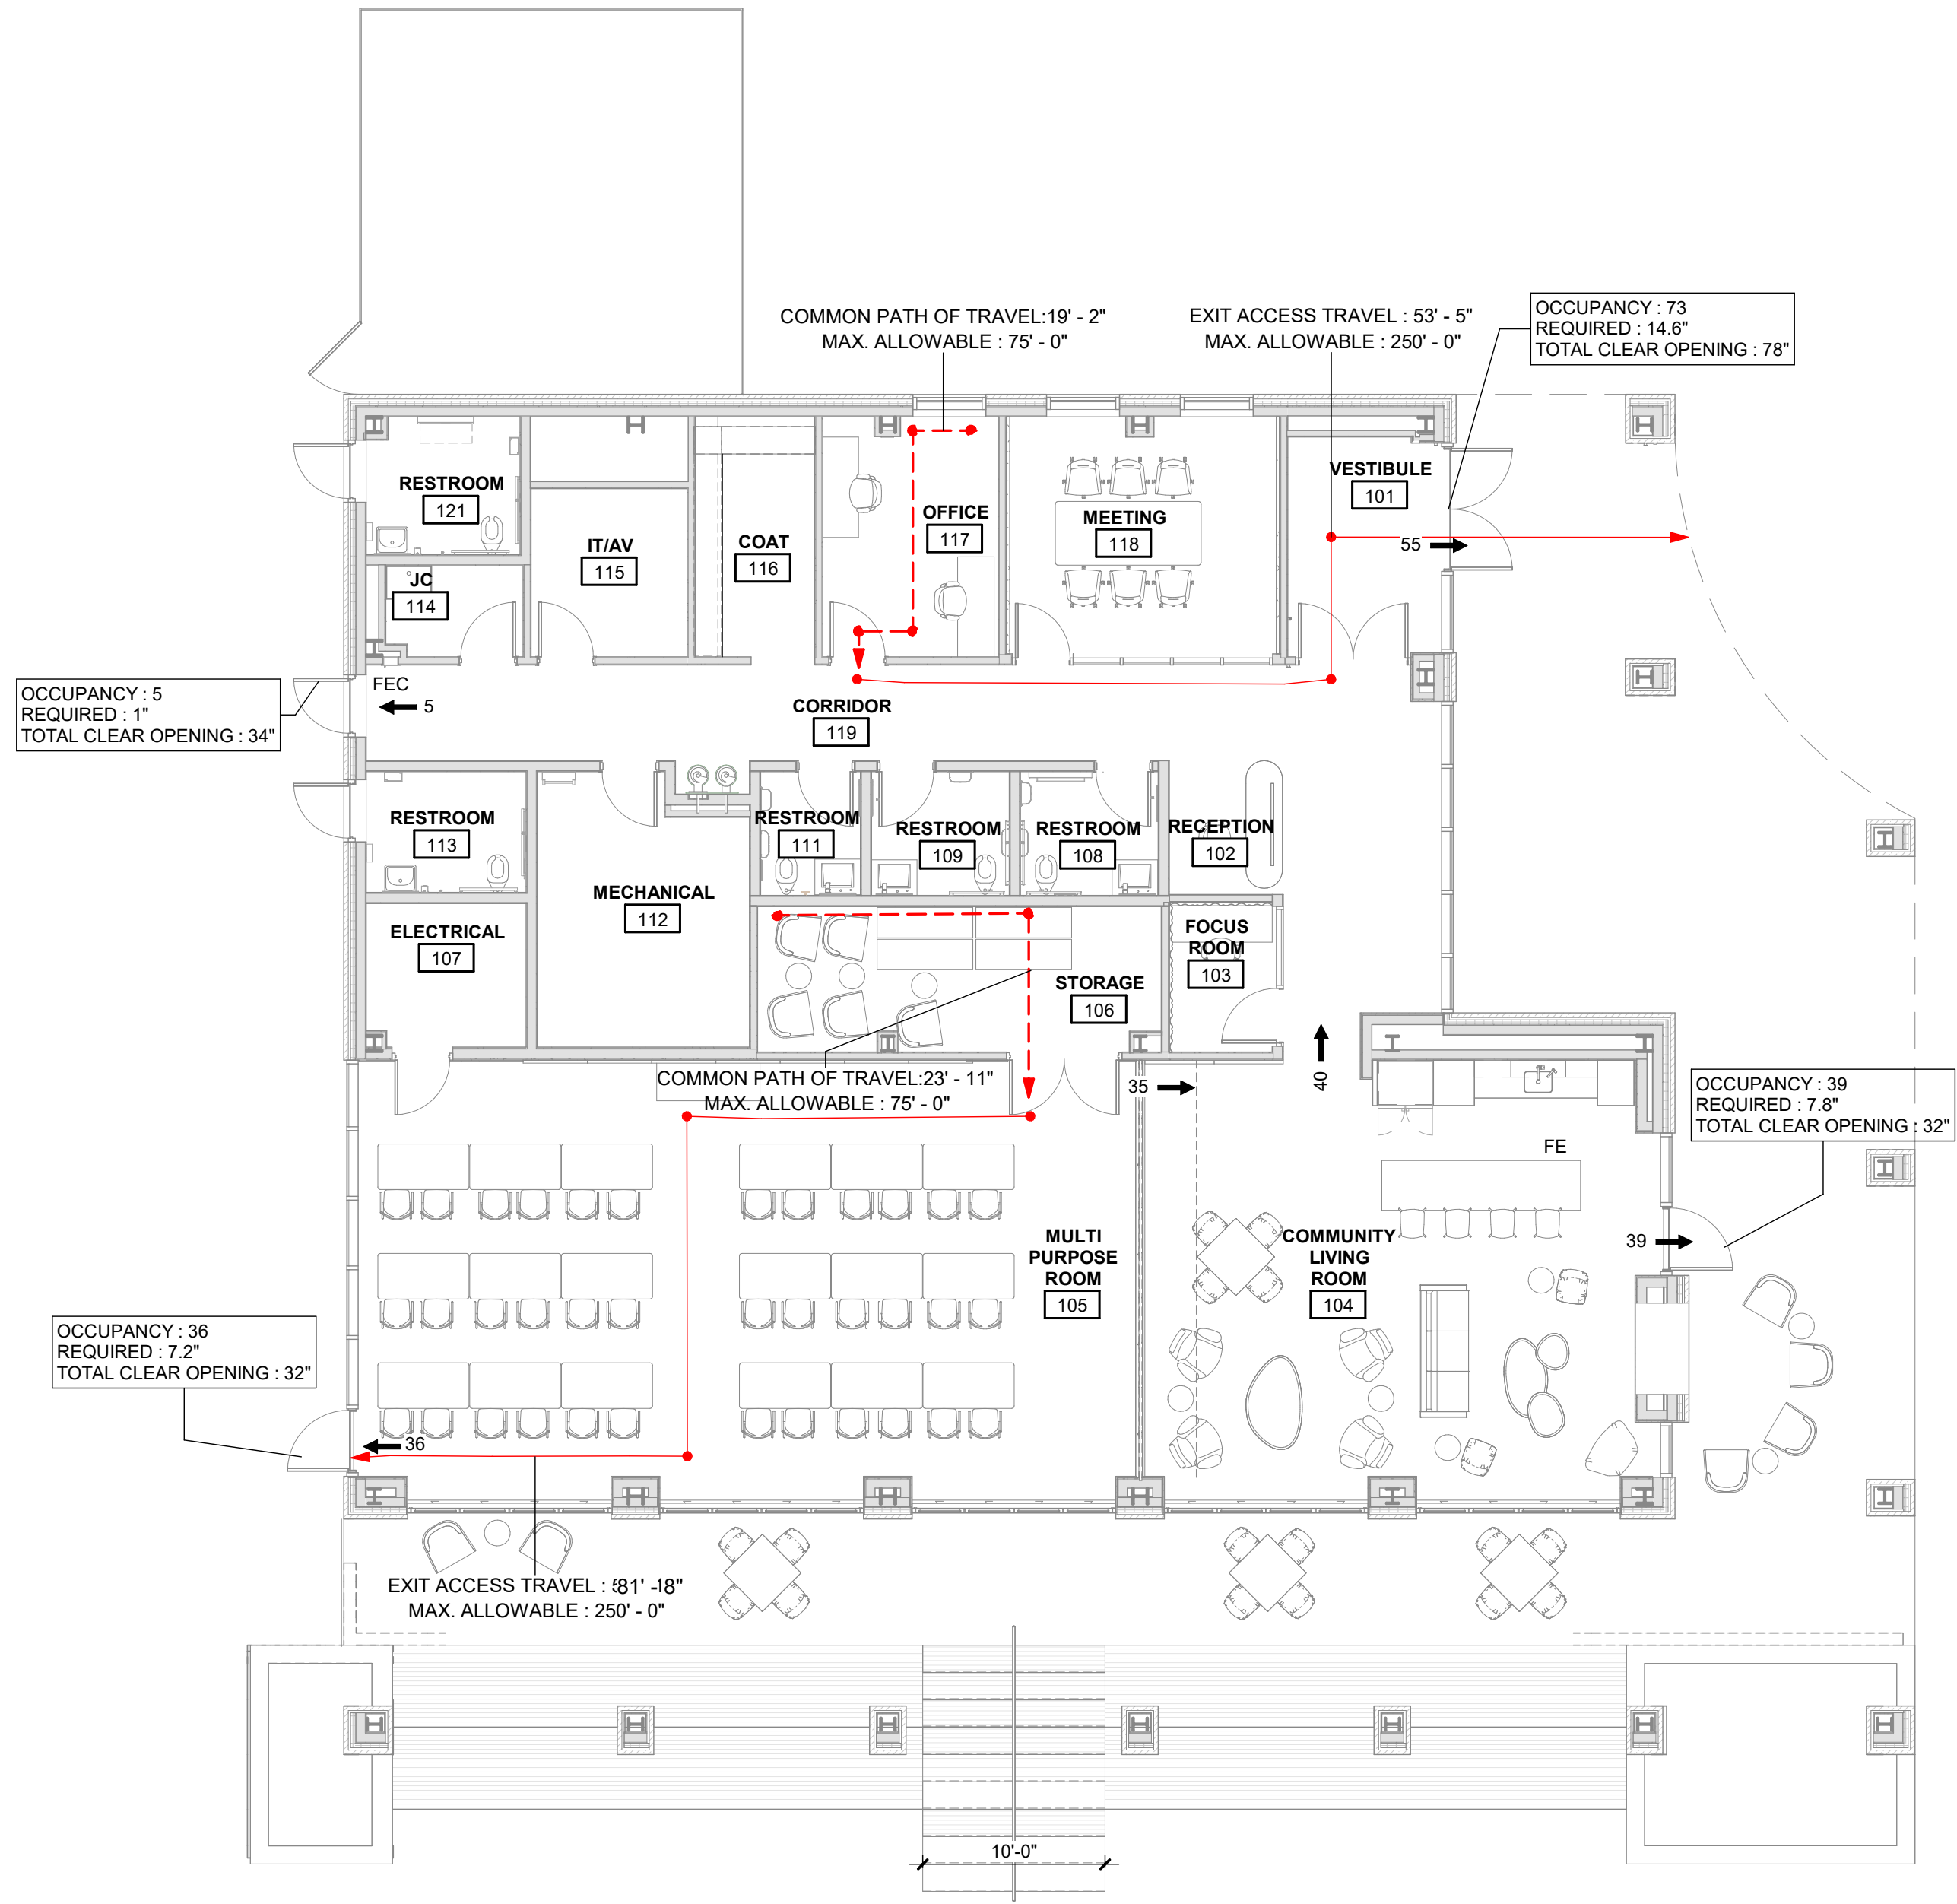

LAKE HOUSE
LIFE SAFETY PLAN - AREA A
SCALE: 1/8" = 1'-0"

CODE LEGEND

# →	ROOM EXITS; # INDICATES OCCUPANT LOAD
FE	FIRE EXTINGUISHER (BRACKET MOUNTED)
FEC	FIRE EXTINGUISHER CABINET
OCCUPANCY : ## REQUIRED : ##" TOTAL CLEAR OPENING : ##"	NUMBER OF OCCUPANTS IN SPACE REQUIRED EGRESS WIDTH (0.15", 0.2", 0.3") TOTAL CLEAR OPENING WIDTH PROVIDED
COMMON PATH OF TRAVEL: X'-X" MAX. ALLOWABLE : X'-X"	COMMON PATH OF TRAVEL : DISTANCE TO REACH A POINT WHERE TWO SEPARATE PATHS TO EXITS ARE AVAILABLE.
EXIT ACCESS TRAVEL : X'-X" MAX. ALLOWABLE : X'-X"	EXIT ACCESS TRAVEL : DISTANCE FROM THE MOST REMOTE POINT TO AN EXIT (INCLUDES COMMON PATH OF TRAVEL)
	MAXIMUM ALLOWABLE DISTANCE PER CODE

BUILDING CODE INFORMATION

APPLICABLE CODES AND STANDARDS

2021 MICHIGAN BUILDING CODE
2021 MICHIGAN PLUMBING CODE
2021 MICHIGAN MECHANICAL CODE
2023 NATIONAL ELECTRICAL CODE (WITH MICHIGAN AMENDMENTS PART 8 RULES)
2021 MICHIGAN COMMERCIAL ENERGY CODE
2019 ANSI/ASHRAES STANDARD 90.1
2021 INTERNATIONAL FIRE CODE
2017 ICC A117.1 ACCESSIBLE AND USABLE BUILDINGS AND FACILITIES
2019 NFPA 72, NATIONAL FIRE ALARM CODE

DESCRIPTION / CLASSIFICATION OF WORK

THE INTENT OF THIS PROJECT IS TO DEVELOP A NEW PUBLIC SPACE AT BELLEVILLE LAKE WITHIN VAN BUREN TOWNSHIP. THE PROJECT INCLUDES THE CONSTRUCTION OF TWO NEW BUILDINGS AND ASSOCIATED SITE IMPROVEMENTS TO SUPPORT COMMUNITY USE AND PUBLIC ACCESS.

LAKE HOUSE IS A NEW ONE-STORY BUILDING DESIGNED TO ACCOMMODATE PUBLIC GATHERINGS AND COMMUNITY EVENTS.

ITEM	CODE REFERENCE
------	----------------

MBC CHAPTER 3 - USE AND OCCUPANCY CLASSIFICATION

USE GROUP: A3 ASSEMBLY (LECTURE HALLS)	302 & 303.4
B BUSINESS (ACCESSORY < 10%)	302 & 304.1

CONSTRUCTION TYPE	
TYPE IIB NONCOMBUSTIBLE, SPRINKLERED	602.2

MBC CHAPTER 5 - GENERAL BUILDING HEIGHTS AND AREAS

ALLOWABLE HEIGHT:	75 FEET	3 STORIES	TABLE 504.3 & 504.4
ACTUAL HEIGHT:	21 FEET	1 STORY	
ALLOWABLE AREA (PER STORY):			TABLE 506.2
A3 ASSEMBLY	38,000 SF		
ACTUAL AREA (SF):	4,044 SF FIRST FLOOR		
	3,644 SF COVERED EXTERIOR PATIO		
	7,688 SF TOTAL		
MIXED USE AND OCCUPANCY			508
NO SEPARATION REQUIRED FOR ACCESSORY OCCUPANCIES			508.2
AGGREGATE < 10% OF FLOOR AREA OF STORY WHERE LOCATED			508.2.3

MBC CHAPTER 6 - TYPES OF CONSTRUCTION

ITEM	RATING	PROVIDED	UL NO.	REMARKS
PRIMARY STRUCTURAL FRAME	0	0	--	TABLE 601
BEARING WALLS - EXTERIOR	0	0	--	TABLE 601
BEARING WALLS - INTERIOR	0	0	--	TABLE 601
NONBEARING WALLS - EXTERIOR (X>30)	0	0	--	TABLE 705.5
NONBEARING WALLS - INTERIOR	0	0	--	TABLE 601
FLOOR CONSTRUCTION	0	0	--	TABLE 601
ROOF CONSTRUCTION	0	0	--	TABLE 601

COMBUSTIBLE MATERIAL IN TYPE II CONSTRUCTION (WOOD MULLIONS, INTERIOR TRIM) SHALL BE CLASS C AND SHALL NOT EXCEED 10% OF SPECIFIC WALL TO WHICH IT IS ATTACHED

603.1.8 & 806.7

MBC CHAPTER 9 - FIRE PROTECTION SYSTEMS

AUTOMATIC SPRINKLER SYSTEMS	
THIS BUILDING IS EQUIPPED WITH AN AUTOMATIC SPRINKLERED SYSTEM	903
	903.1.1

MBC CHAPTER 10 - MEANS OF EGRESS

DESIGN OCCUPANT LOAD			TABLE 1004.1.2
MAXIMUM FLOOR AREA ALLOWANCES PER OCCUPANT			
FUNCTION OF SPACE	TOTAL AREA GROSS/NET	AREA PER OCCUPANT	OCCUPANT LOAD
ASSEMBLY, UNCONCENTRATED	1,950	15 GROSS	130
BUSINESS AREAS (RECEPTION/OFFICE/FOCUS)	234	150 GROSS	2
ACCESSORY STORAGE, MECH EQUIPMENT	694	300 GROSS	3
TOTALS	2,878 GSF		135 OCC

MEANS OF EGRESS COMPONENTS (SPRINKLERED*)

1005.3.1 & 1005.3.2

COMPONENT	OCCUPANTS	WIDTH	REQUIRED	PROVIDED
EXTERIOR EXIT DOORS	135	0.2"	27"	176" CLEAR

MBC CHAPTER 29 - PLUMBING SYSTEMS


2021 MICHIGAN PLUMBING CODE	TABLE 403.1
MINIMUM NUMBER OF REQUIRED PLUMBING FIXTURES	

TOTAL OCCUPANTS: 35 ± 68 EACH GENDER

TWO SINGLE-OCCUPANT EXTERIOR RESTROOMS ARE EXCLUDED FROM THE REQUIRED FIXTURE COUNT CALCULATION.

TOTAL FIXTURES	REQUIRED	PROVIDED
MALE	1 WC 1 LAV	0 WC + 0 UR 0 LAV
FEMALE	2 WC 1 LAV	0 WC 0 LAV
SINGLE-OCCUPANT RESTROOM	3 WC	3 LAV
TOTAL	3 WC 2 LAV	3 WC + 0 UR 3 LAV
	1 DF 1 SS	1 DF 1 SS

KEY PLAN

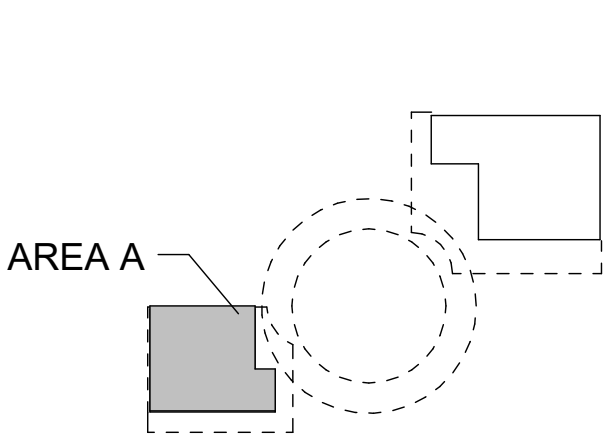

REVISIONS		
10/27/2026	A2	ADDENDUM NO. 2

10/12/2026	BIDS & PERMIT
09/21/2026	CD PEER REVIEW
09/09/2026	CD TEAM REVIEW
08/10/2026	CD 50% PROGRESS
08/22/2026	DD OWNER REVIEW
08/15/2026	DD PEER REVIEW
06/08/2026	DD 90 % PROGRESS
05/18/2026	DD 50 % PROGRESS
02/23/2026	SD OWNER REVIEW
02/13/2026	SD PEER REVIEW
02/09/2026	SD PROGRESS REVIEW

Drawn By	IOLKHOVESKA
Designer	IOLKHOVETSKA
Reviewer	WLAPSON
Manager	CKRETOVIC


Hard copy is intended to be 24"x36" when plotted. Scale(s) indicated and graphic quality may not be accurate for any other size.

PROJECT NO.
2500281

SHEET NO.

G201

PLT: INFO: Z:\2025\2500281\CAD\C102_C102_2500281.DWG LAYOUT: C102 DATE: 10/26/2026 TIME: 2:49:50 PM USER: DRHOTON

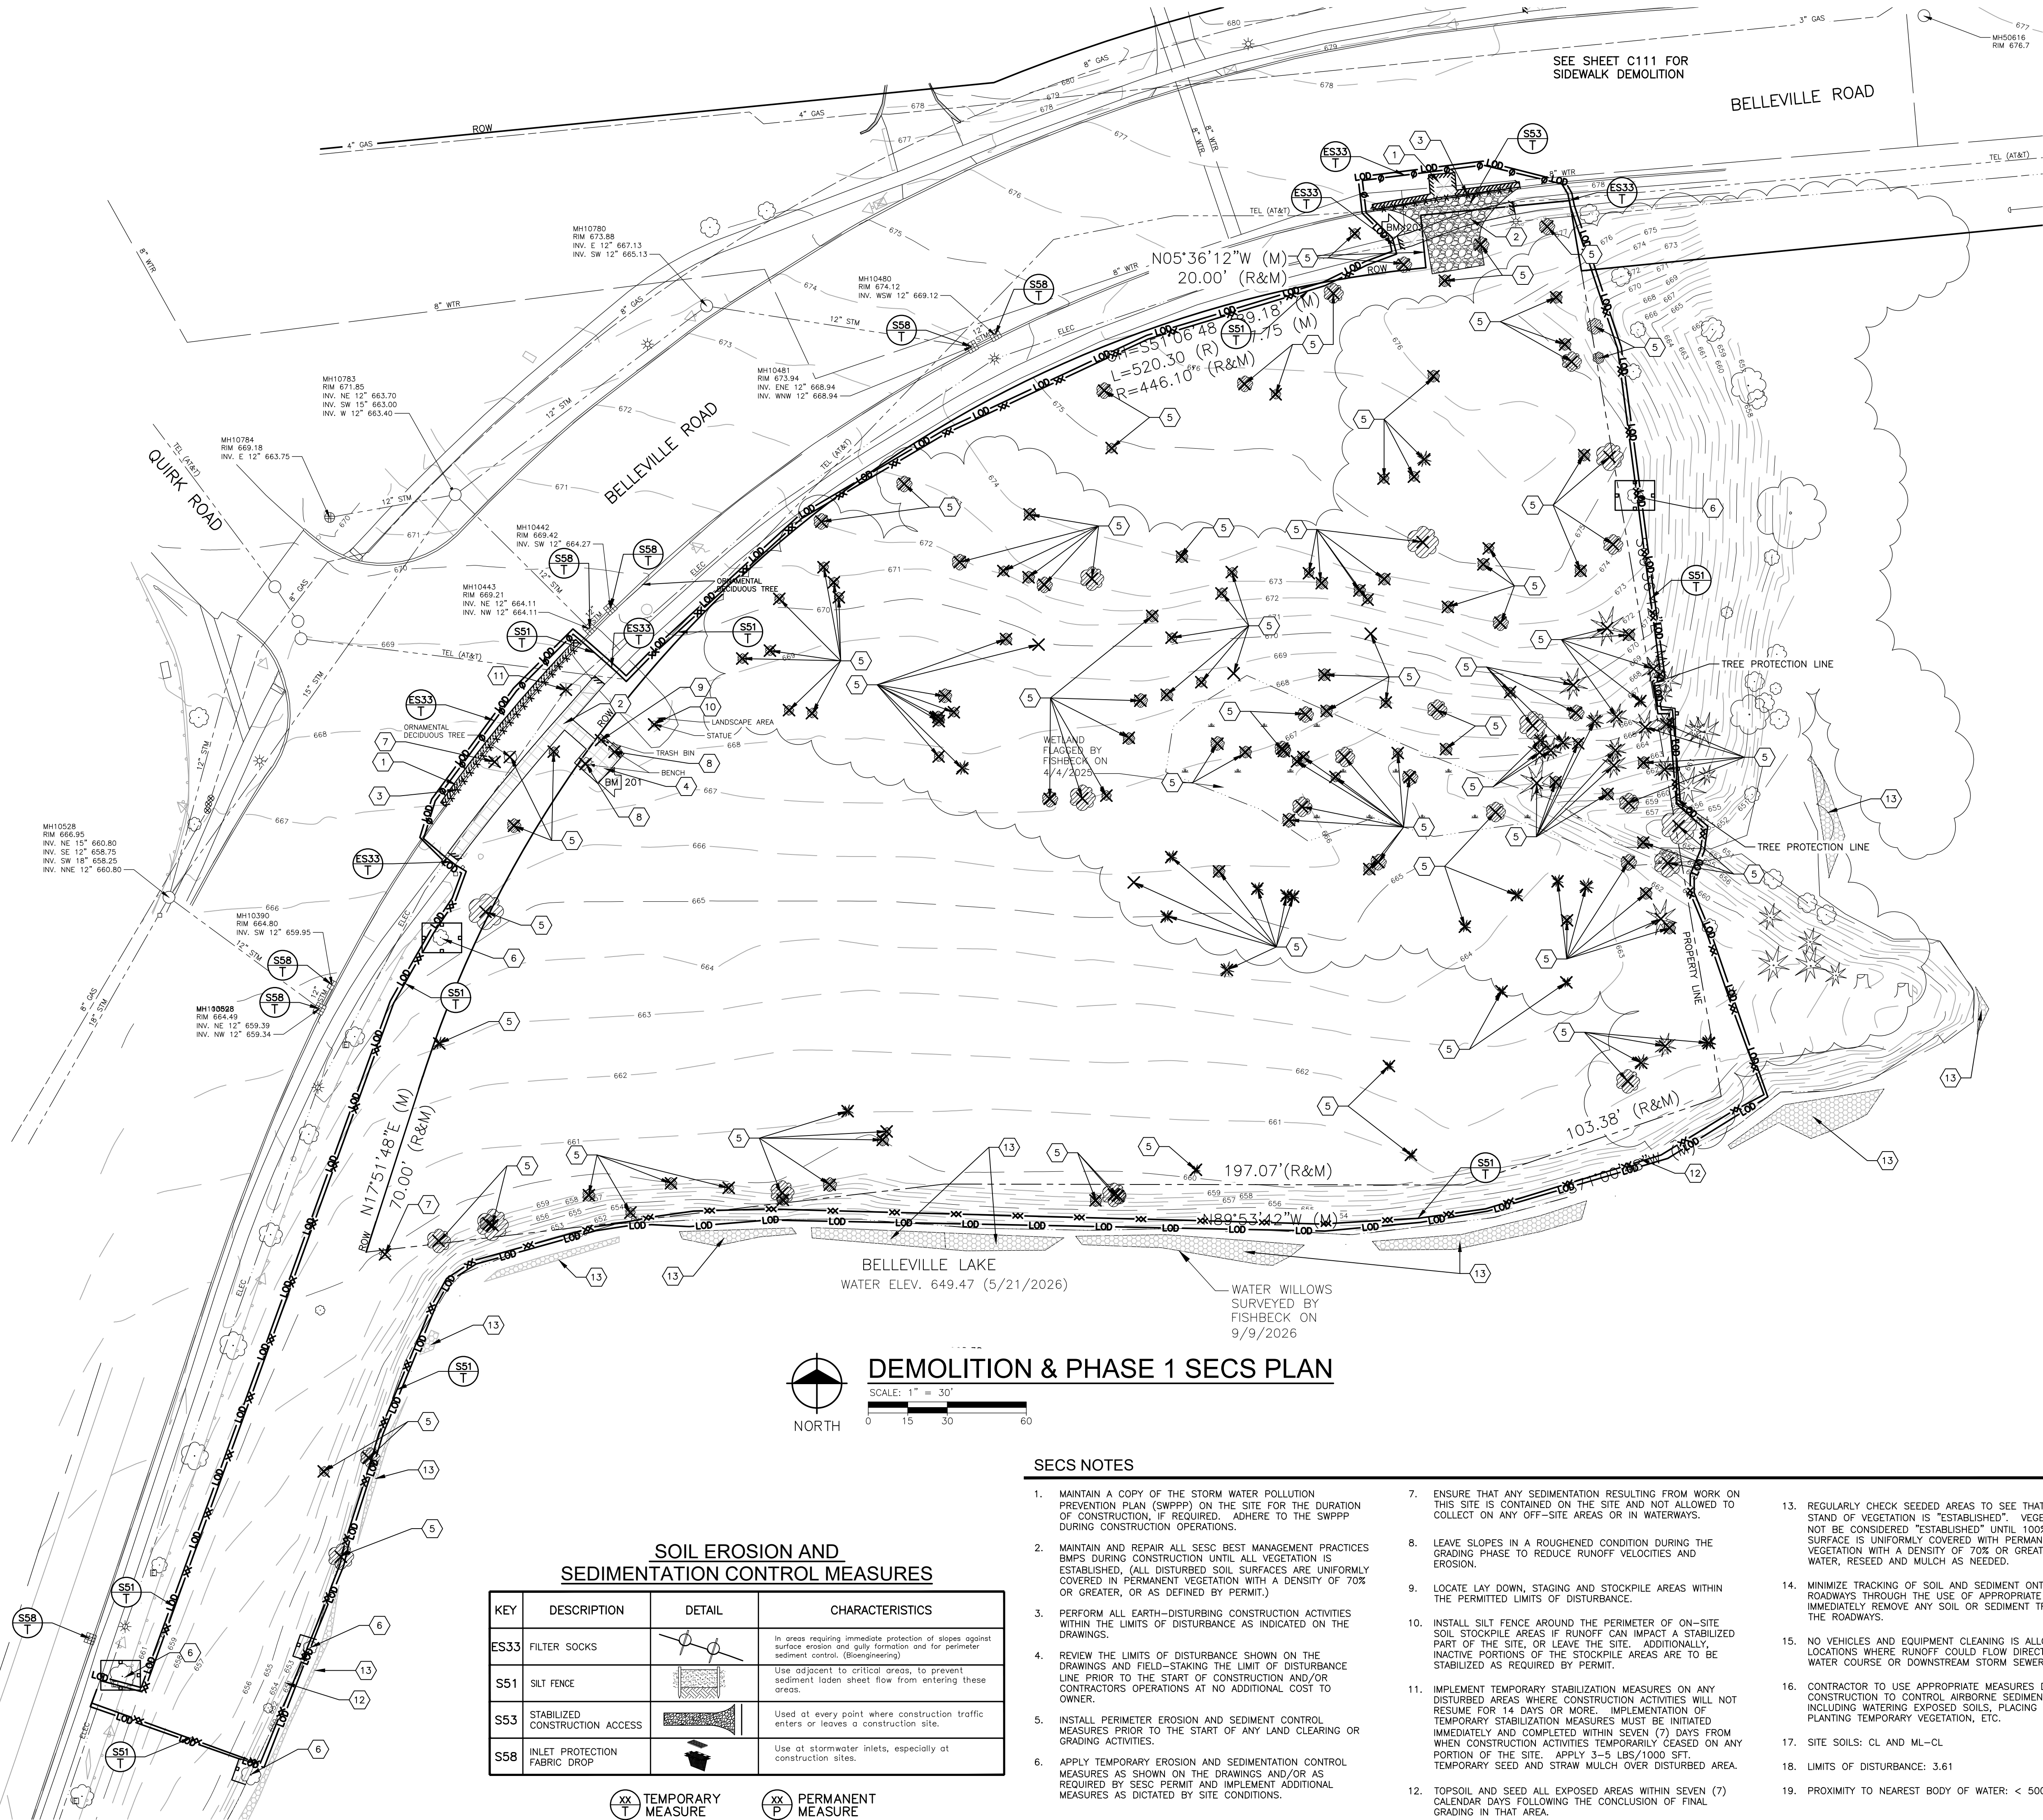

SOIL EROSION AND SEDIMENTATION CONTROL MEASURES

KEY	DESCRIPTION	DETAIL	CHARACTERISTICS
ES33	FILTER SOCKS		In areas requiring immediate protection of slopes against surface erosion and gully formation and for perimeter sediment control. (Bioengineering)
S51	SILT FENCE		Use adjacent to critical areas, to prevent sediment laden sheet flow from entering these areas.
S53	STABILIZED CONSTRUCTION ACCESS		Used at every point where construction traffic enters or leaves a construction site.
S58	INLET PROTECTION FABRIC DROP		Use at stormwater inlets, especially at construction sites.

TEMPORARY MEASURE

PERMANENT MEASURE

SECS NOTES

1. MAINTAIN A COPY OF THE STORM WATER POLLUTION PREVENTION PLAN (SWPPP) ON THE SITE FOR THE DURATION OF CONSTRUCTION, IF REQUIRED. ADHERE TO THE SWPPP DURING CONSTRUCTION OPERATIONS.
2. MAINTAIN AND REPAIR ALL SECS BEST MANAGEMENT PRACTICES BMPs DURING CONSTRUCTION UNTIL ALL VEGETATION IS ESTABLISHED. (ALL DISTURBED SOIL SURFACES ARE UNIFORMLY COVERED IN PERMANENT VEGETATION WITH A DENSITY OF 70% OR GREATER, OR AS DEFINED BY PERMIT.)
3. PERFORM ALL EARTH-DISTURBING CONSTRUCTION ACTIVITIES WITHIN THE LIMITS OF DISTURBANCE AS INDICATED ON THE DRAWINGS.
4. REVIEW THE LIMITS OF DISTURBANCE SHOWN ON THE DRAWINGS AND FIELD-STAKING THE LIMIT OF DISTURBANCE LINE PRIOR TO THE START OF CONSTRUCTION AND/OR CONTRACTORS OPERATIONS AT NO ADDITIONAL COST TO OWNER.
5. INSTALL PERIMETER EROSION AND SEDIMENT CONTROL MEASURES PRIOR TO THE START OF ANY LAND CLEARING OR GRADING ACTIVITIES.
6. APPLY TEMPORARY EROSION AND SEDIMENTATION CONTROL MEASURES AS SHOWN ON THE DRAWINGS AND/OR AS REQUIRED BY SECS PERMIT AND IMPLEMENT ADDITIONAL MEASURES AS DICTATED BY SITE CONDITIONS.
7. ENSURE THAT ANY SEDIMENTATION RESULTING FROM WORK ON THIS SITE IS CONTAINED ON THE SITE AND NOT ALLOWED TO COLLECT ON ANY OFF-SITE AREAS OR IN WATERWAYS.
8. LEAVE SLOPES IN A ROUGHENED CONDITION DURING THE GRADING PHASE TO REDUCE RUNOFF VELOCITIES AND EROSION.
9. LOCATE LAY DOWN, STAGING AND STOCKPILE AREAS WITHIN THE PERMITTED LIMITS OF DISTURBANCE.
10. INSTALL SILT FENCE AROUND THE PERIMETER OF ON-SITE SOIL STOCKPILE AREAS IF RUNOFF CAN IMPACT A STABILIZED PORT OF THE SITE, OR LEAVE THE SITE. ADDITIONALLY, INACTIVE PORTIONS OF THE STOCKPILE AREAS ARE TO BE STABILIZED AS REQUIRED BY PERMIT.
11. IMPLEMENT TEMPORARY STABILIZATION MEASURES ON ANY DISTURBED AREAS WHERE CONSTRUCTION ACTIVITIES WILL NOT RESUME FOR 14 DAYS OR MORE. IMPLEMENTATION OF TEMPORARY STABILIZATION MEASURES MUST BE INITIATED IMMEDIATELY AND COMPLETED WITHIN SEVEN (7) DAYS FROM WHEN CONSTRUCTION ACTIVITIES TEMPORARILY CEASED ON ANY PORTION OF THE SITE. APPLY 3-5 LBS/1000 SFT. TEMPORARY SEED AND STRAW MULCH OVER DISTURBED AREA.
12. TOPSOIL AND SEED ALL EXPOSED AREAS WITHIN SEVEN (7) CALENDAR DAYS FOLLOWING THE CONCLUSION OF FINAL GRADING IN THAT AREA.
13. REGULARLY CHECK SEEDING AREAS TO SEE THAT A GOOD STAND OF VEGETATION IS "ESTABLISHED". VEGETATION WILL NOT BE CONSIDERED "ESTABLISHED" UNTIL 100% OF THE SOIL SURFACE IS UNIFORMLY COVERED WITH PERMANENT VEGETATION WITH A DENSITY OF 70% OR GREATER. FERTILIZE, WATER, RESEED AND MULCH AS NEEDED.
14. MINIMIZE TRACKING OF SOIL AND SEDIMENT ONTO OFF-SITE ROADWAYS THROUGH THE USE OF APPROPRIATE MEASURES. IMMEDIATELY REMOVE ANY SOIL OR SEDIMENT TRACKED ONTO THE ROADWAYS.
15. NO VEHICLES AND EQUIPMENT CLEANING IS ALLOWED AT LOCATIONS WHERE RUNOFF COULD FLOW DIRECTLY INTO A WATER COURSE OR DOWNSTREAM STORM SEWER.
16. CONTRACTOR TO USE APPROPRIATE MEASURES DURING CONSTRUCTION TO CONTROL AIRBORNE SEDIMENTATION INCLUDING WATERING EXPOSED SOILS, PLACING WIND FENCING, PLANTING TEMPORARY VEGETATION, ETC.
17. SITE SOILS: CL AND ML-CL
18. LIMITS OF DISTURBANCE: 3.61
19. PROXIMITY TO NEAREST BODY OF WATER: < 500 FEET

BENCH MARKS

- BENCH MARK 201 ELEVATION: 668.38
MAG NAIL IN SOUTHEASTERLY CORNER OF CONCRETE PAD ON SOUTHERLY SIDE OF BELLEVILLE ROAD, DIRECTLY ACROSS FROM QUIRK ROAD (TO BE REMOVED)
- BENCH MARK 202 ELEVATION: 679.17
ARROW ON HYDRANT ON SOUTHERLY SIDE OF BELLEVILLE ROAD 400' EAST OF INTERSECTION OF BELLEVILLE ROAD AND QUIRK ROAD

DEMOLITION SYMBOL LEGEND

- SAWCUT
 CURB REMOVAL
 REMOVE PIPE
 REMOVE OBJECT
 REMOVE CONCRETE PAVEMENT
 TREE PROTECTION
 TREE REMOVAL

SECS SYMBOL LEGEND

- 725'- EXISTING MAJOR CONTOUR
 -724'- EXISTING MINOR CONTOUR
 SILT FENCE
 EROSION EEL OR FILTER LOG
 LOD - LIMITS OF DISTURBANCE

DEMOLITION NOTES

1. FIELD VERIFY THE EXTENT OF REMOVALS AND DEMOLITION PRIOR TO CONSTRUCTION. NOTIFY ENGINEER OF ANY DEVIATIONS FROM INFORMATION SHOWN.
2. PRIOR TO CONSTRUCTION ALL FENCING, BARRICADES, ENCLOSURES, ETC., MUST BE INSTALLED AND APPROVED BY OWNER OR CONSTRUCTION MANAGER.
3. DISPOSE OF DEMOLITION AND EXCAVATION MATERIALS IN ACCORDANCE WITH CONTRACT DOCUMENTS.
4. SOIL EROSION AND SEDIMENTATION CONTROL MEASURES MUST BE IN PLACE PRIOR TO STARTING REMOVALS AND DEMOLITION.
5. UNLESS SPECIFICALLY NOTED FOR REMOVAL ON THE PLANS, PROTECT ALL SIDEWALKS, DRIVES, CULVERTS, DRAINAGE STRUCTURES, AND ABOVE AS WELL AS BELOW GRADE UTILITIES. REMOVE AND REPLACE ALL SUCH ITEMS DAMAGED OR DESTROYED DURING CONSTRUCTION WITH NEW AT NO ADDITIONAL COST TO THE OWNER.
6. PROTECT EXISTING TREES TO REMAIN WITH TEMPORARY FENCING AT THE DRIP LINE. NO GROUND DISTURBANCE OR STORAGE OF MATERIAL/EQUIPMENT SHALL OCCUR WITHIN THE DRIP LINE LIMITS.
7. COORDINATE REMOVAL OR REPLACEMENT OF ELECTRICAL, TELEPHONE, CABLE TV, WATER, FIBER OPTIC CABLE AND/OR GAS LINES WITH THE AFFECTED UTILITY COMPANY. PROVIDE ADEQUATE TIME FOR RELOCATION AND CLOSE COORDINATION WITH THE UTILITY COMPANY AS NECESSARY TO PROVIDE A SMOOTH TRANSITION IN UTILITY SERVICE. PAY CLOSE ATTENTION TO EXISTING UTILITIES WITHIN THE CONSTRUCTION LIMITS. GIVE NOTICE TO ALL UTILITY COMPANIES REGARDING DESTRUCTION AND REMOVAL OF ALL SERVICE LINES AND CAP ALL LINES BEFORE PROCEEDING WITH THE WORK.
8. PERFORM CLEARING, GRUBBING, TREE AND STUMP REMOVAL, TOPSOIL REMOVAL AND STOCKPILING IN ACCORDANCE WITH THE CONTRACT DOCUMENTS.
9. BEFORE REMOVING OR ABANDONING ANY UTILITY PIPES, VERIFY NEW UTILITY PIPE HAS BEEN INSTALLED, TESTED AND IS OPERATIONAL.
10. THE LOCATIONS OF ALL EXISTING UTILITIES SHOWN ON THIS DRAWING HAVE BEEN DETERMINED FROM THE BEST INFORMATION AVAILABLE AND ARE GIVEN FOR THE CONVENIENCE OF THE CONTRACTOR. VERIFY CRITICAL INVERT INFORMATION PRIOR TO BEGINNING CONSTRUCTION.
11. SAWCUT AND REPLACE DAMAGE CAUSED TO SURROUNDING AREA PAVEMENT OUTSIDE THE CONSTRUCTION LIMITS AT NO ADDITIONAL COST TO THE OWNER.
12. COORDINATE SEQUENCING AND PHASING OF DEMOLITION WITH CONSTRUCTION MANAGER.
13. SAWCUT CURB AND GUTTER AND SIDEWALKS TO NEAREST JOINT.
14. PICK UP DEBRIS WITHIN PROPERTY LIMITS WEEKLY OR AS NEEDED.

DEMOLITION KEY NOTES

1. SAWCUT AND REMOVE CONCRETE PAVING FULL DEPTH.
2. SAWCUT AND REMOVE CONCRETE SIDEWALK TO NEAREST JOINT.
3. REMOVE CONCRETE CURB AND GUTTER.
4. REMOVE CONCRETE PAD.
5. REMOVE TREE.
6. PROTECT TREE.
7. REMOVE SIGN.
8. REMOVE AND SALVAGE BENCH.
9. REMOVE AND SALVAGE TRASH BIN.
10. REMOVE AND SALVAGE STATUE.
11. REMOVE AND SALVAGE LIGHT POST.
12. REMOVE RIPRAP ALONG BANK.
13. DO NOT DISTURB WATER WILLOWS.

Van Buren Charter Township

Van Buren Township, MI

The Lakeside Park

REVISONS		
10/28/2026	A2	ADDENDUM NO. 2

10/12/2026	BIDS & PERMITS
09/21/2026	CD PEER REVIEW
09/08/2026	CD TEAM REVIEW
08/10/2026	CD 50% PROGRESS
06/22/2026	DD OWNER REVIEW
06/15/2026	DD PEER REVIEW
06/08/2026	DD 90 % PROGRESS
05/18/2026	DD 50 % PROGRESS
02/23/2026	SD OWNER REVIEW
02/13/2026	SD PEER REVIEW
02/09/2026	SD PROGRESS REVIEW

Drawn By ARAMIREZ
Designer DRHOTON
Reviewer ERANDOLPH
Manager OKRETOVIC

Hard copy is intended to be 24"x36" when plotted. Scale(s) indicated and graphic quality may not be accurate for any other size.


PROJECT NO.
2500281

SHEET NO.

C102

©Copyright 2026
All Rights Reserved

PLT: INFO: Z:\2025\2500281\CAD\CD\C201_2500281.DWG LAYOUT: C201 DATE: 10/25/2026 TIME: 2:55:48 PM USER: DRHOTON

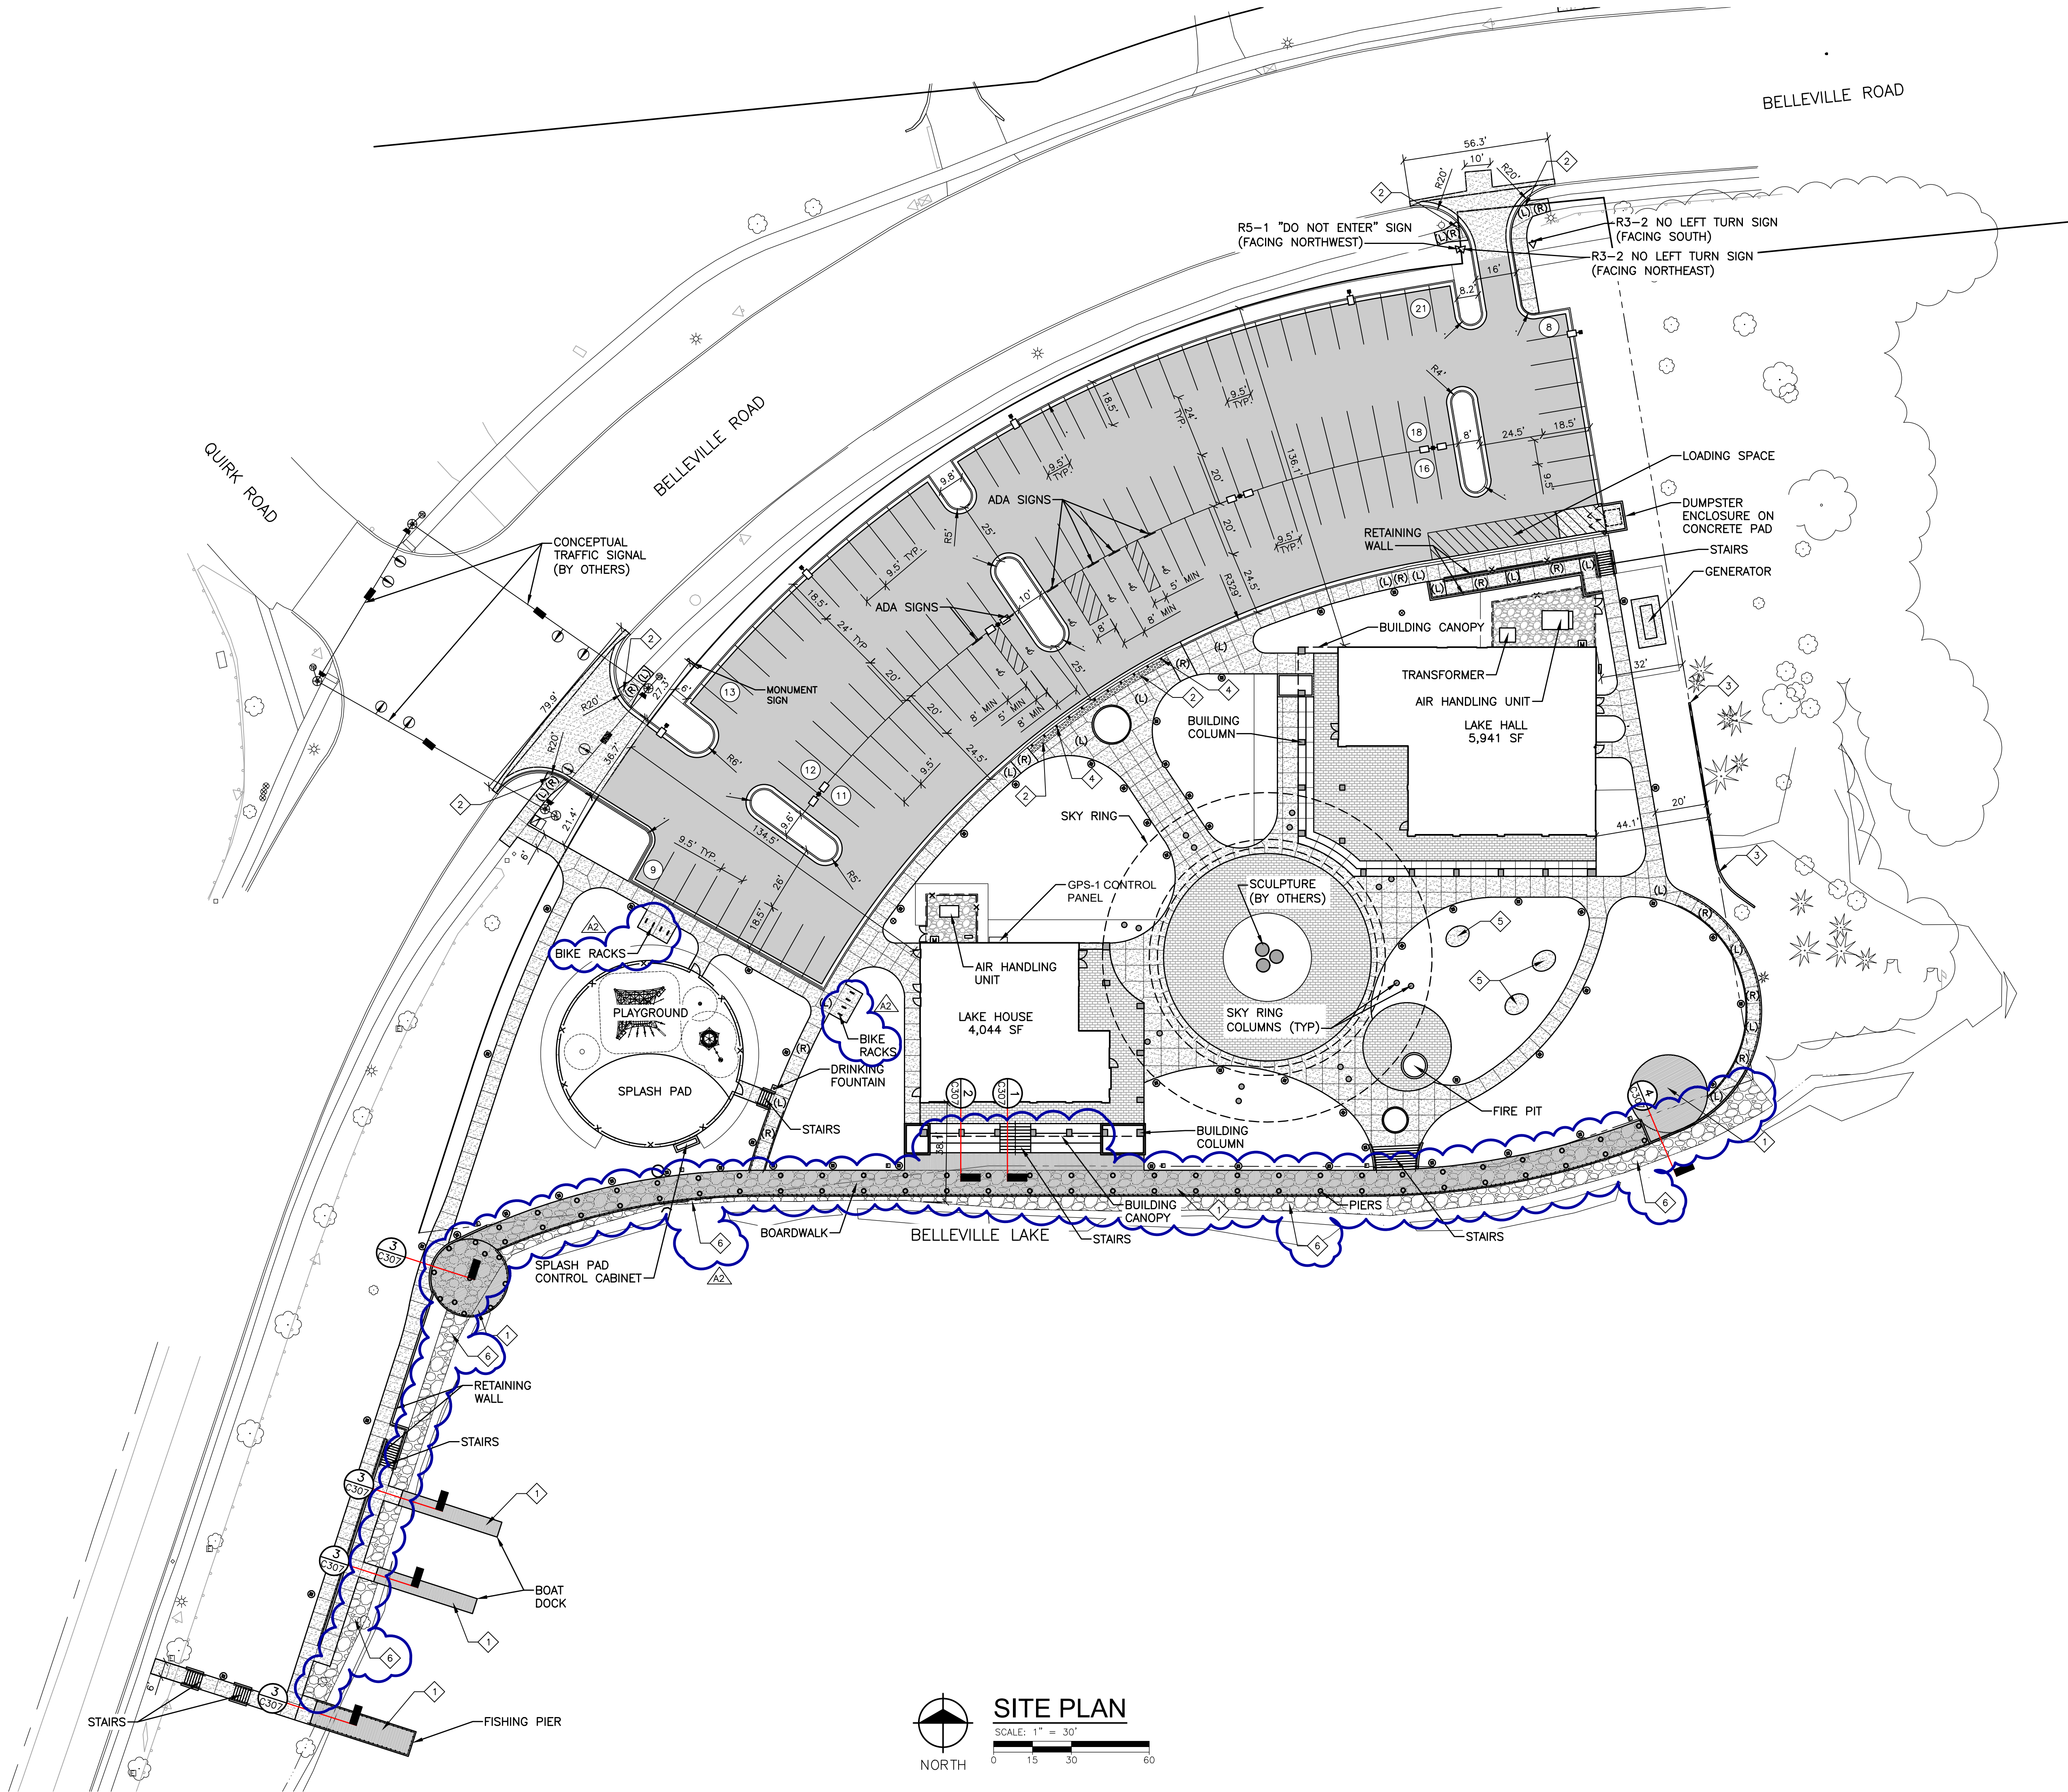

SYMBOL LEGEND

- SPECIAL PAVEMENT (SEE LANDSCAPE)
- COMPOSITE DECKING (SEE STRUCTURAL)
- 4" THICK CONCRETE SIDEWALK
- ASPHALT PAVEMENT
- CONCRETE PAVEMENT
- GRAVEL PAVEMENT
- DETECTABLE WARNING STRIP
- STANDARD CURB AND GUTTER
- STANDARD CURB PAN
- PARKING SPACE COUNT
- SITE LIGHT POLE OR LIGHT BOLLARD
- BOARDWALK PIERS (SEE STRUCTURAL)
- FENCE (SEE LANDSCAPE)
- SIGN

NOTES

- DIMENSIONS ARE TO BACK OF CURB, OUTSIDE FACE OF BUILDING, AND EDGE OF PAVEMENT UNLESS NOTED OTHERWISE.
- KEEP THE APPROVED AND/OR MOST CURRENT SET OF PROJECT DRAWINGS ON SITE AT ALL TIMES. CONTRACTOR TO CONFIRM THEY ARE IN POSSESSION OF THE MOST CURRENT DRAWING FILES.
- SEE LANDSCAPE FOR LAYOUT OF SIDEWALK AND SPECIAL PAVEMENT.
- SEE STRUCTURAL FOR LAYOUT OF DECKING.
- PAVED SURFACES, WALKWAYS, SIGNS, LIGHTING AND OTHER STRUCTURES AND SURFACES SHALL BE MAINTAINED IN A SAFE, ATTRACTIVE CONDITION AS ORIGINALLY DESIGNED AND CONSTRUCTED. PARKING LOT STRIPING AND MARKINGS SHALL BE MAINTAINED IN CLEARLY VISIBLE CONDITION.

PARKING QUANTITIES

MAXIMUM OCCUPANCY:

LAKE HOUSE: 133 PEOPLE
LAKE HALL: 187 PEOPLE

REQUIRED PARKING:

321 PEOPLE X 1 SPACE PER / 3 PEOPLE = 107 SPACES

PROVIDED PARKING:

102 STANDARD SPACES
6 BARRIER FREE SPACES (5 REQUIRED)
108 TOTAL SPACES

KEY NOTES

- BOARDWALK. SEE STRUCTURAL.
- DETECTABLE WARNING STRIP.
- RETAINING WALL WITH GUARDRAIL.
- BOLLARDS (11).
- CONCRETE SLAB FOR TABLE.
- REPLACE RIPRAP TO EDGE OF WATER. APPROXIMATELY 500 CY.

Van Buren Charter Township

Van Buren Township, MI

The Lakeside Park

REVISIONS		
10/27/2026	A2	ADDENDUM NO. 2

10/12/2026	BIDS & PERMITS
09/21/2026	CD PEER REVIEW
09/09/2026	CD TEAM REVIEW
08/10/2026	CD 50% PROGRESS
06/22/2026	DD OWNER REVIEW
06/15/2026	DD PEER REVIEW
06/08/2026	DD 90% PROGRESS
05/18/2026	DD 50% PROGRESS
02/23/2026	SD OWNER REVIEW
02/13/2026	SD PEER REVIEW
02/09/2026	SD PROGRESS REVIEW

Drawn By: DRHOTON
Designer: DRHOTON
Reviewer: ERANDOLPH
Manager: OKRETOVIC

Hard copy is intended to be 24"x36" when plotted. Scale(s) indicated and graphic quality may not be accurate for any other size.


PROJECT NO.
2500281

SHEET NO.

C201

© Copyright 2026
All Rights Reserved

PLOT INFO: Z:\2025\2500281\CAD\C301_2500281.DWG LAYOUT: C301 DATE: 10/27/2026 TIME: 10:44:02 AM USER: CMAYER

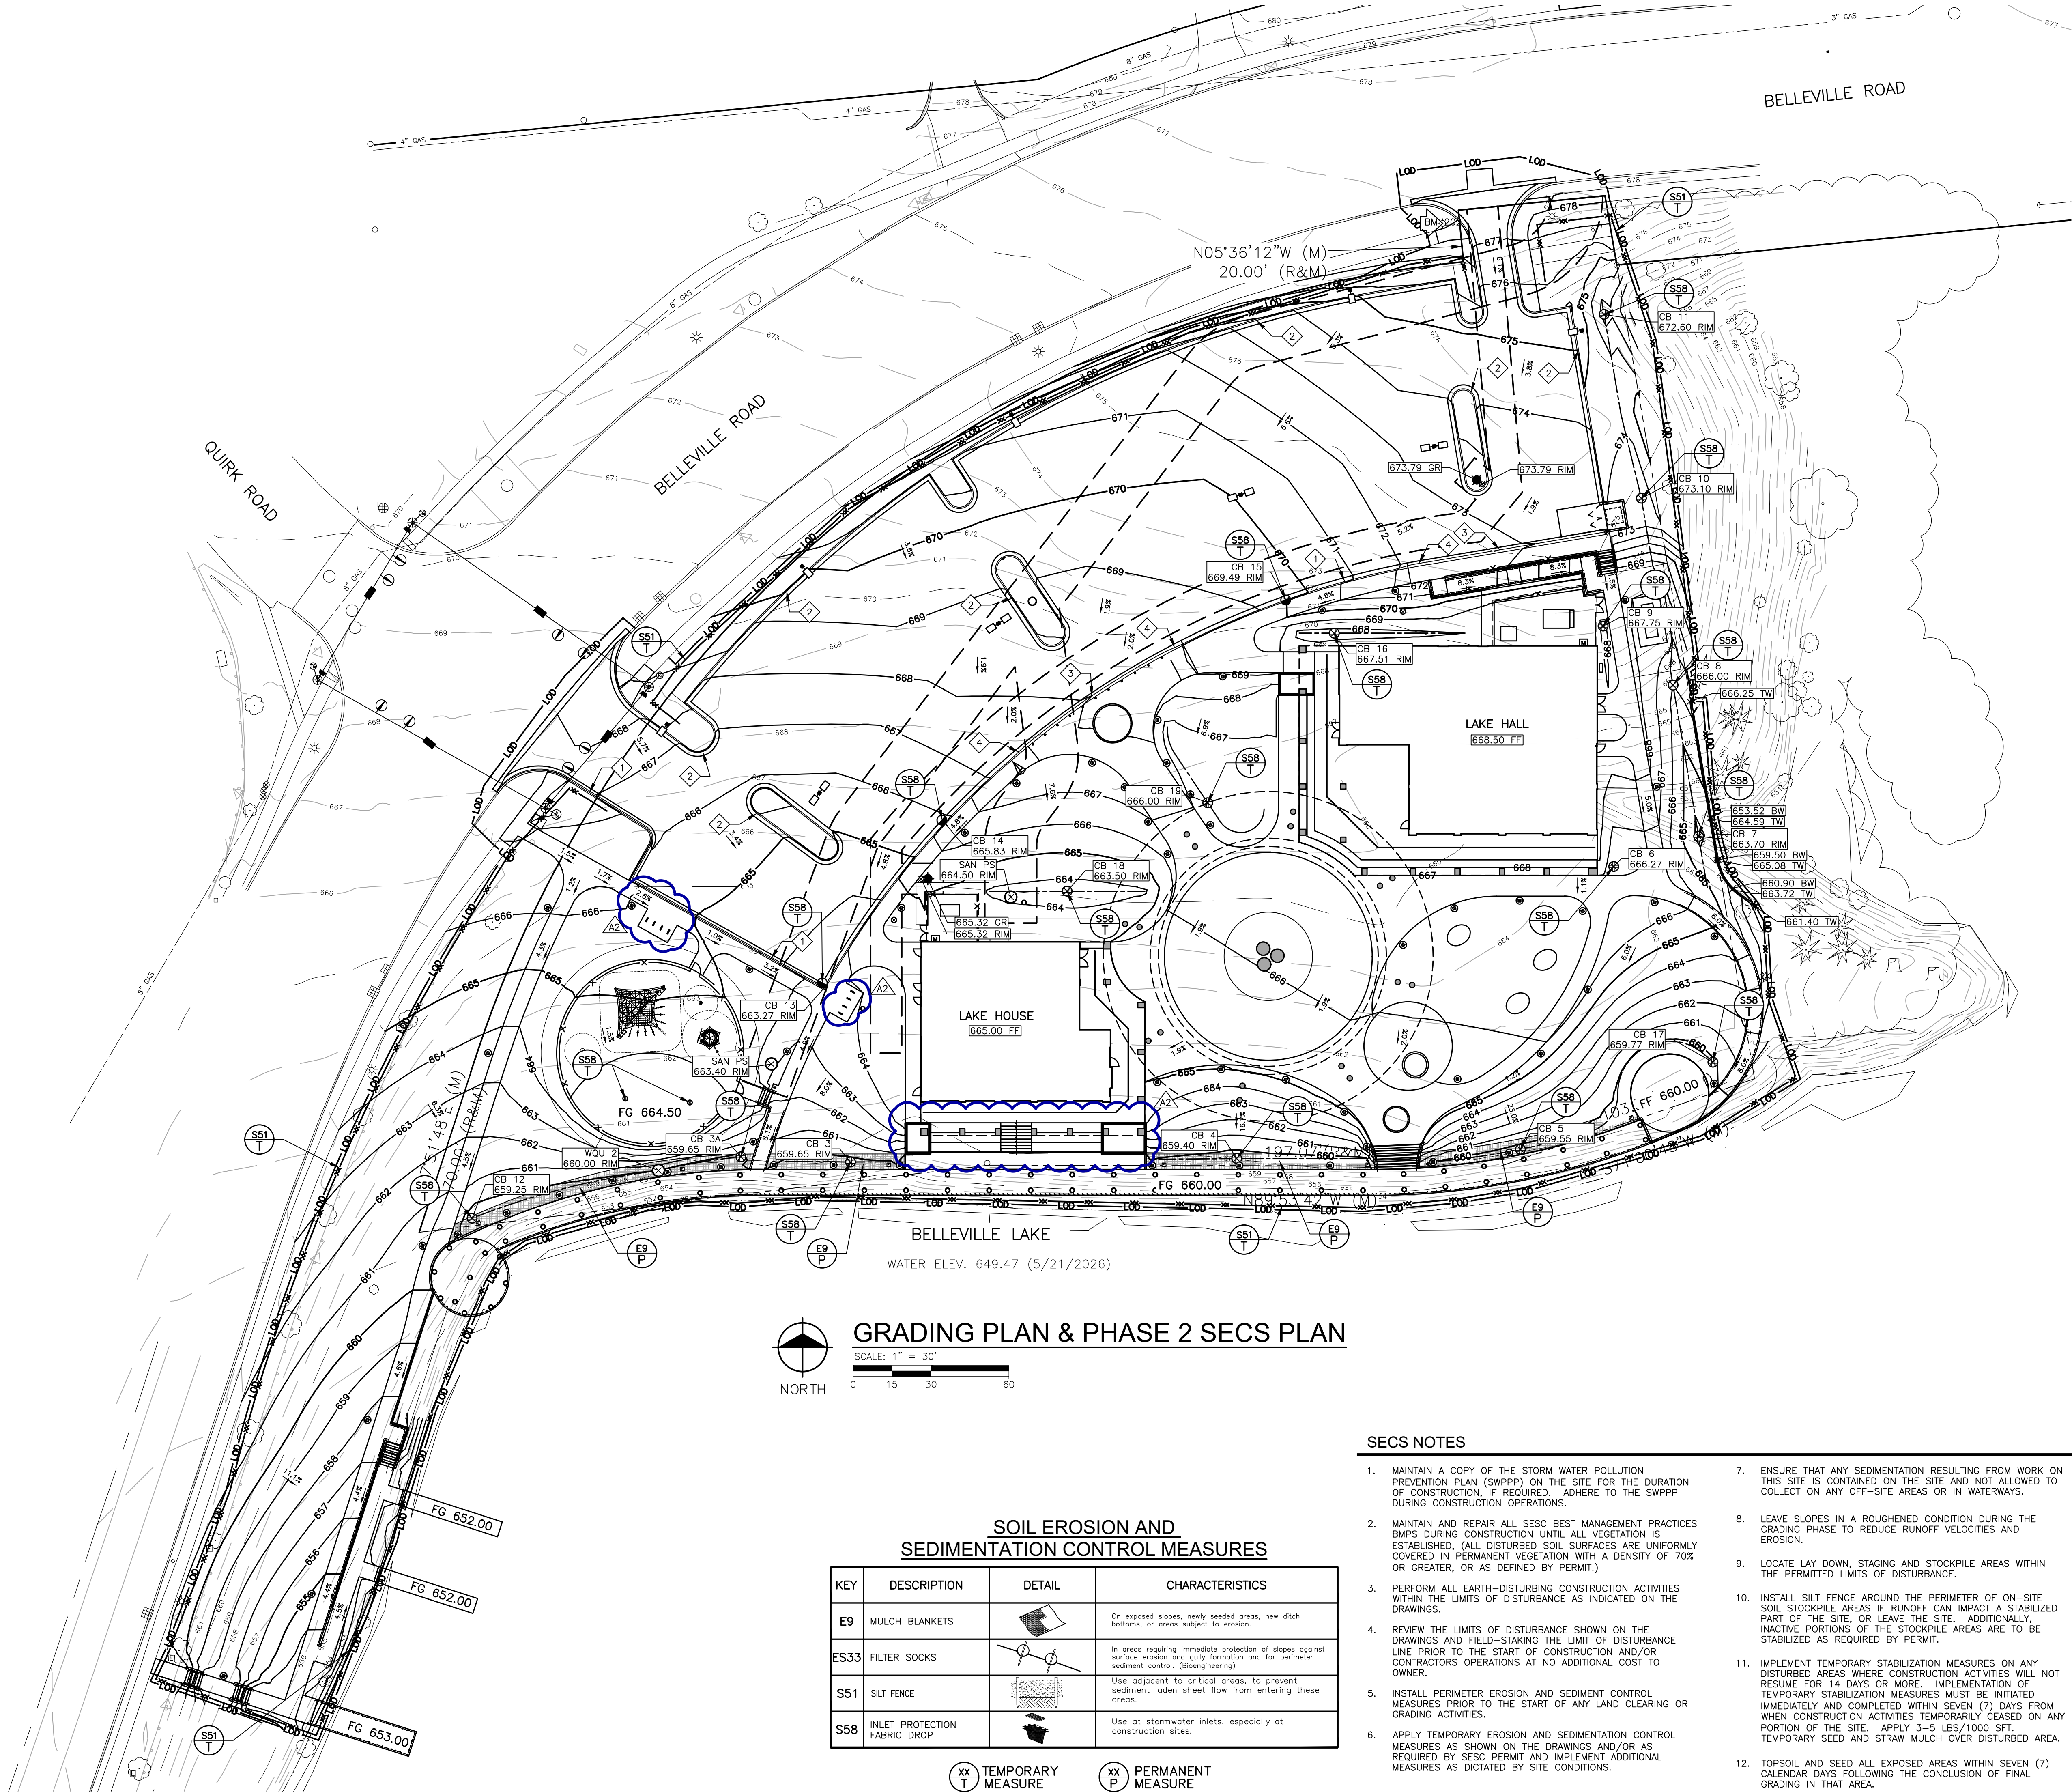

GRADING PLAN & PHASE 2 SECS PLAN

SCALE: 1" = 30'
0 15 30 60

SOIL EROSION AND SEDIMENTATION CONTROL MEASURES

KEY	DESCRIPTION	DETAIL	CHARACTERISTICS
E9	MULCH BLANKETS		On exposed slopes, newly seeded areas, new ditch bottoms, or areas subject to erosion.
ES33	FILTER SOCKS		In areas requiring immediate protection of slopes against surface erosion and gully formation and for perimeter sediment control. (Bioengineering)
S51	SILT FENCE		Use adjacent to critical areas, to prevent sediment laden sheet flow from entering these areas.
S58	INLET PROTECTION FABRIC DROP		Use at stormwater inlets, especially at construction sites.

TEMPORARY MEASURE

PERMANENT MEASURE

SECS NOTES

1. MAINTAIN A COPY OF THE STORM WATER POLLUTION PREVENTION PLAN (SWPPP) ON THE SITE FOR THE DURATION OF CONSTRUCTION, IF REQUIRED. ADHERE TO THE SWPPP DURING CONSTRUCTION OPERATIONS.
2. MAINTAIN AND REPAIR ALL SESC BEST MANAGEMENT PRACTICES BMPs DURING CONSTRUCTION UNTIL ALL VEGETATION IS ESTABLISHED. (ALL DISTURBED SOIL SURFACES ARE UNIFORMLY COVERED IN PERMANENT VEGETATION WITH A DENSITY OF 70% OR GREATER, OR AS DEFINED BY PERMIT.)
3. PERFORM ALL EARTH-DISTURBING CONSTRUCTION ACTIVITIES WITHIN THE LIMITS OF DISTURBANCE AS INDICATED ON THE DRAWINGS.
4. REVIEW THE LIMITS OF DISTURBANCE SHOWN ON THE DRAWINGS AND FIELD-STAKING THE LIMIT OF DISTURBANCE LINE PRIOR TO THE START OF CONSTRUCTION AND/OR CONTRACTORS OPERATIONS AT NO ADDITIONAL COST TO OWNER.
5. INSTALL PERIMETER EROSION AND SEDIMENT CONTROL MEASURES PRIOR TO THE START OF ANY LAND CLEARING OR GRADING ACTIVITIES.
6. APPLY TEMPORARY EROSION AND SEDIMENTATION CONTROL MEASURES AS SHOWN ON THE DRAWINGS AND/OR AS REQUIRED BY SESC PERMIT AND IMPLEMENT ADDITIONAL MEASURES AS DICTATED BY SITE CONDITIONS.
7. ENSURE THAT ANY SEDIMENTATION RESULTING FROM WORK ON THIS SITE IS CONTAINED ON THE SITE AND NOT ALLOWED TO COLLECT ON ANY OFF-SITE AREAS OR IN WATERWAYS.
8. LEAVE SLOPES IN A ROUGHENED CONDITION DURING THE GRADING PHASE TO REDUCE RUNOFF VELOCITIES AND EROSION.
9. LOCATE LAY DOWN, STAGING AND STOCKPILE AREAS WITHIN THE PERMITTED LIMITS OF DISTURBANCE.
10. INSTALL SILT FENCE AROUND THE PERIMETER OF ON-SITE SOIL STOCKPILE AREAS IF RUNOFF CAN IMPACT A STABILIZED PART OF THE SITE, OR LEAVE THE SITE. ADDITIONALLY, INACTIVE PORTIONS OF THE STOCKPILE AREAS ARE TO BE STABILIZED AS REQUIRED BY PERMIT.
11. IMPLEMENT TEMPORARY STABILIZATION MEASURES ON ANY DISTURBED AREAS WHERE CONSTRUCTION ACTIVITIES WILL NOT RESUME FOR 14 DAYS OR MORE. IMPLEMENTATION OF TEMPORARY STABILIZATION MEASURES MUST BE INITIATED IMMEDIATELY AND COMPLETED WITHIN SEVEN (7) DAYS FROM WHEN CONSTRUCTION ACTIVITIES TEMPORARILY CEASED ON ANY PORTION OF THE SITE. APPLY 3-5 LBS/1000 SFT. TEMPORARY SEED AND STRAW MULCH OVER DISTURBED AREA.
12. TOPSOIL AND SEED ALL EXPOSED AREAS WITHIN SEVEN (7) CALENDAR DAYS FOLLOWING THE CONCLUSION OF FINAL GRADING IN THAT AREA.
13. REGULARLY CHECK SEEDED AREAS TO SEE THAT A GOOD STAND OF VEGETATION IS "ESTABLISHED". VEGETATION WILL NOT BE CONSIDERED "ESTABLISHED" UNTIL 100% OF THE SOIL SURFACE IS UNIFORMLY COVERED WITH PERMANENT VEGETATION WITH A DENSITY OF 70% OR GREATER. FERTILIZE, WATER, RESEED AND MULCH AS NEEDED.
14. MINIMIZE TRACKING OF SOIL AND SEDIMENT ONTO OFF-SITE ROADWAYS THROUGH THE USE OF APPROPRIATE MEASURES. IMMEDIATELY REMOVE ANY SOIL OR SEDIMENT TRACKED ONTO THE ROADWAYS.
15. NO VEHICLES AND EQUIPMENT CLEANING IS ALLOWED AT LOCATIONS WHERE RUNOFF COULD FLOW DIRECTLY INTO A WATER COURSE OR DOWNSTREAM STORM SEWER.
16. CONTRACTOR TO USE APPROPRIATE MEASURES DURING CONSTRUCTION TO CONTROL AIRBORNE SEDIMENTATION INCLUDING WATERING EXPOSED SOILS, PLACING WIND FENCING, PLANTING TEMPORARY VEGETATION, ETC.
17. SITE SOILS: CL AND ML-CL
18. LIMITS OF DISTURBANCE: 3.61
19. PROXIMITY TO NEAREST BODY OF WATER: < 500 FEET

BENCH MARKS

BENCH MARK 201 ELEVATION: 668.38
MAG NAIL IN SOUTHEASTERLY CORNER OF CONCRETE PAD ON SOUTHERLY SIDE OF BELLEVILLE ROAD, DIRECTLY ACROSS FROM QUIRK ROAD (TO BE REMOVED)

BENCH MARK 202 ELEVATION: 679.17
ARROW ON HYDRANT ON SOUTHERLY SIDE OF BELLEVILLE ROAD 400' EAST OF INTERSECTION OF BELLEVILLE ROAD AND QUIRK ROAD

GRADING SYMBOL LEGEND

- 725- EXISTING MAJOR CONTOUR
- 724- EXISTING MINOR CONTOUR
- 725- PROPOSED MAJOR CONTOUR
- 724- PROPOSED MINOR CONTOUR
- 724.50 XX SPOT ELEVATION
- EM EDGE OF METAL
- EW EDGE OF WALK
- FF FINISH FLOOR
- GR GRADE ELEVATION
- GU GUTTER
- HP HIGH POINT
- TC TOP OF CURB
- TP TOP OF PAVEMENT
- TW TOP OF WALL

SECS SYMBOL LEGEND


- 725- EXISTING MAJOR CONTOUR
- 724- EXISTING MINOR CONTOUR
- XX SILT FENCE
- EROSION EEL OR FILTER LOG
- L00 LIMITS OF DISTURBANCE
- MULCH BLANKET

GRADING NOTES

1. FINISH GRADE OF SOIL EDGES ALONG PAVEMENT TO MATCH EDGE OF PAVEMENT.
2. STRIP AND STOCKPILE TOPSOIL FROM GRADING AREAS. USE STOCKPILED TOPSOIL AND IMPORTED TOPSOIL AS NECESSARY FOR SURFACE RESTORATION.
3. GRADES SHOWN ARE FINAL SURFACE GRADES AFTER COMPLETION OF SURFACE IMPROVEMENTS AND PLACEMENT OF TOPSOIL.
4. ADA PARKING AREAS NOT TO EXCEED 2.0% SLOPE IN ALL DIRECTIONS.
5. GRADE AREAS AT SITE PERIMETER TO MATCH GRADES OF ADJACENT PARCELS.
6. REMOVE EXCESS SOIL FROM SITE AND DISPOSE OF PROPERLY IN ACCORDANCE WITH APPLICABLE REGULATIONS.
7. PROVIDE TEMPORARY GRADING FEATURES SUCH AS BERMS, SWALES, SUMPS AND BASINS TO MANAGE INTERIM STORM WATER RUNOFF DURING CONSTRUCTION PROCESS. STORM WATER RUNOFF LEAVING THE SITE SHALL MEET ALL FEDERAL, STATE AND LOCAL QUALITY REQUIREMENTS.

KEY NOTES

1. STANDARD CURB AND GUTTER.
2. INVERTED CURB AND GUTTER.
3. GUTTER PAN.
4. CURB TYPE TRANSITION, 5' MIN. LENGTH

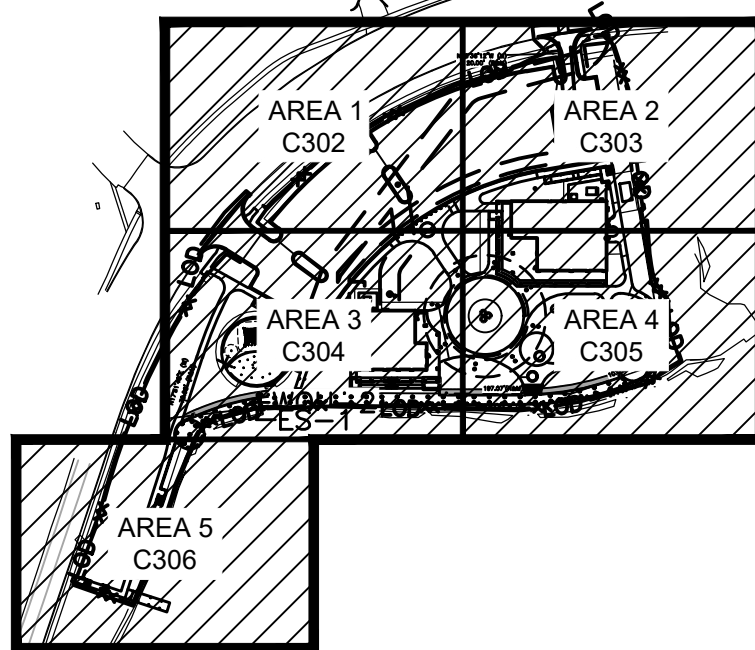

ENLARGED GRADING KEYPLAN

SCALE: NONE

REVISIONS

10/26/2026 AZ ADDENDUM NO. 2

10/12/2026	BIDS & PERMITS
09/21/2026	CD PEER REVIEW
09/09/2026	CD TEAM REVIEW
08/10/2026	CD 50% PROGRESS
08/22/2026	DD OWNER REVIEW
06/15/2026	DD PEER REVIEW
06/08/2026	DD 90 % PROGRESS
05/18/2026	DD 50 % PROGRESS
02/23/2026	SD OWNER REVIEW
02/13/2026	SD PEER REVIEW
02/09/2026	SD PROGRESS REVIEW

Drawn By ARAMIREZ
Designer DRHOTON
Reviewer ERANDOLPH
Manager OKRETOVIC

Hard copy is intended to be 24"x36" when plotted. Scale(s) indicated and graphic quality may not be accurate for any other size.

PROJECT NO.

2500281

SHEET NO.

C301


© Copyright 2026
All Rights Reserved

Van Buren Charter Township

Van Buren Township, MI

The Lakeside Park

fishbeck
Engineers | Architects | Scientists | Constructors

 

SCALE: NONE

10/26/2026	A2	ADDENDUM NO. 2
------------	----	----------------

10/12/2026	BIDS & PERMITS
09/21/2026	CD PEER REVIEW
09/09/2026	CD TEAM REVIEW
08/10/2026	CD 50% PROGRESS
06/22/2026	DD OWNER REVIEW
06/15/2026	DD PEER REVIEW
06/08/2026	DD 90 % PROGRESS
05/18/2026	DD 50 % PROGRESS
02/23/2026	SD OWNER REVIEW
02/13/2026	SD PEER REVIEW
02/09/2026	SD PROGRESS REVIEW

Drawn By	ARAMIREZ
Designer	DRHOTON
Reviewer	ERANDOLPH
Manager	CKRETOVIC


Hard copy is intended to be 24"x36" when plotted. Scale(s) indicated and graphic quality may not be accurate for any other size.

PROJECT NO.

2500281

SHEET NO

C304

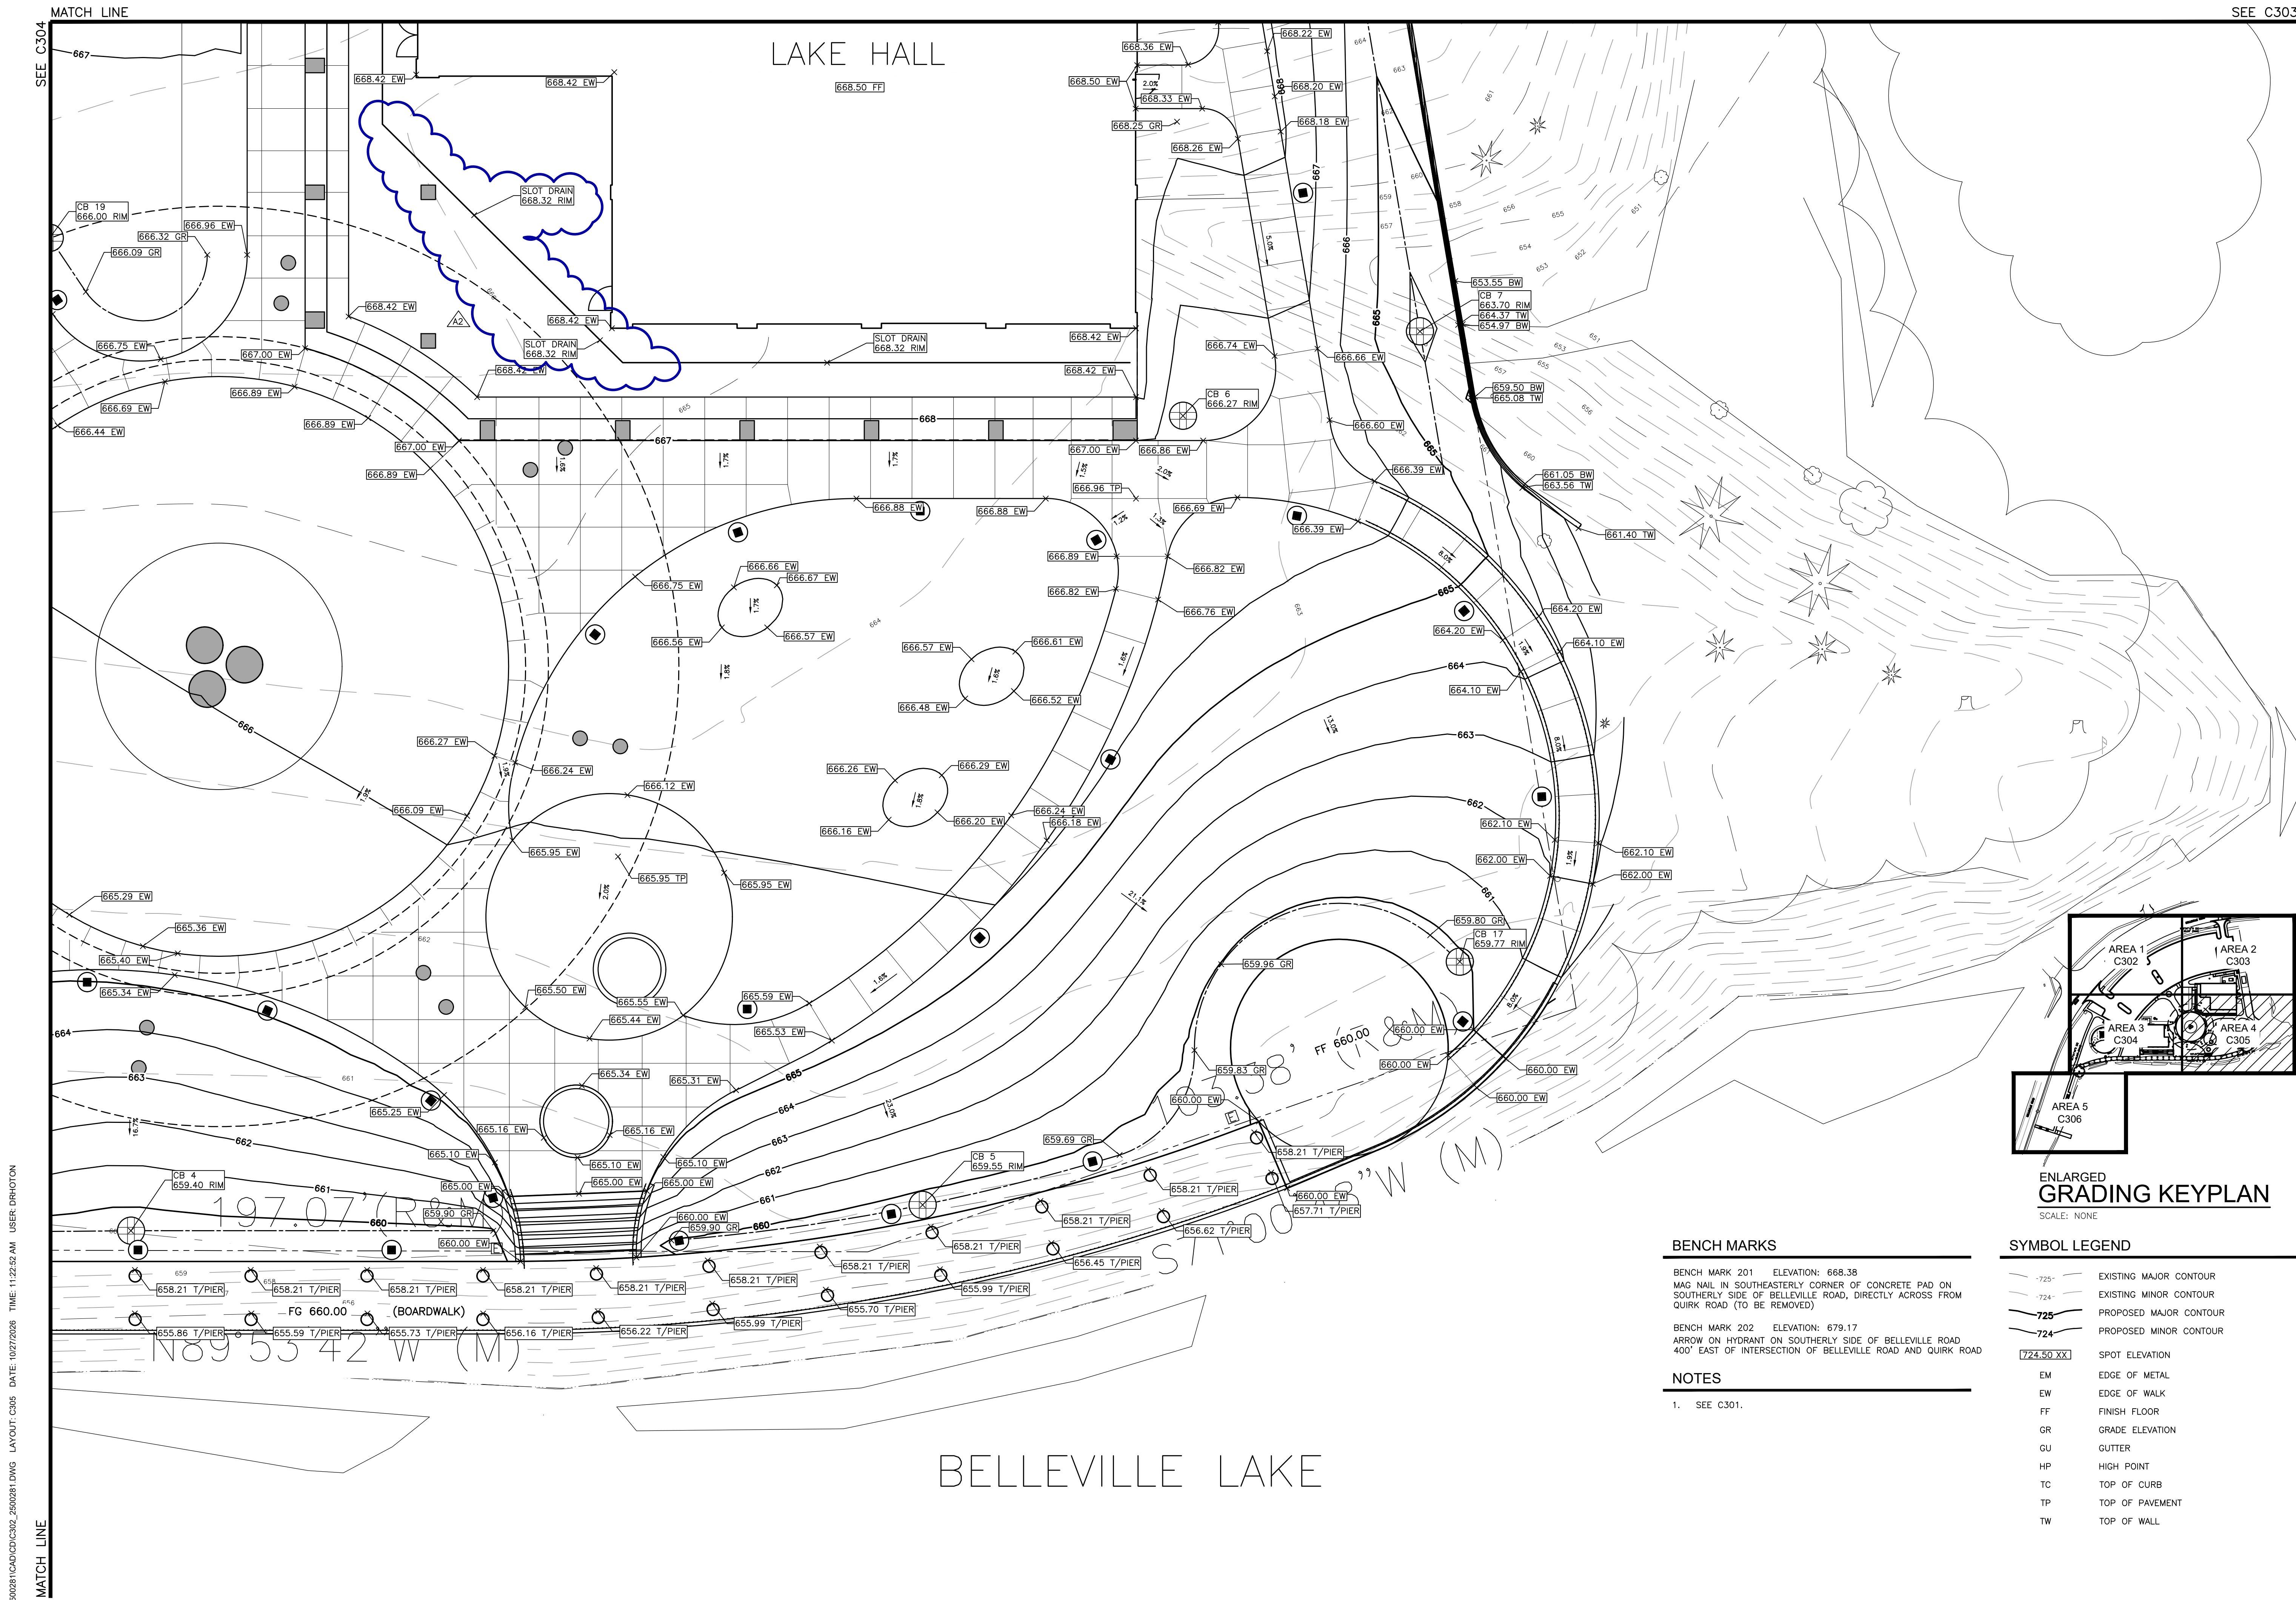

SEE C304

MATCH LINE

PLT INFO: Z:\2025\2500281\CAD\C304_2500281.DWG LAYOUT: C305 DATE: 10/27/2026 TIME: 11:22:52 AM USER: DRHOTON

MATCH LINE

SEE C303

Van Buren Charter Township
Van Buren Township, MI
The Lakeside Park

REVISIONS	
10/27/2026	A2 [ADDENDUM NO. 2]

10/12/2026	BIDS & PERMITS
09/21/2026	CD PEER REVIEW
09/08/2026	CD TEAM REVIEW
08/10/2026	CD 50% PROGRESS
06/22/2026	DD OWNER REVIEW
06/15/2026	DD PEER REVIEW
06/08/2026	DD 90% PROGRESS
05/18/2026	DD 50% PROGRESS
02/23/2026	SD OWNER REVIEW
02/13/2026	SD PEER REVIEW
02/09/2026	SD PROGRESS REVIEW

Drawn By	ARAMIREZ
Designer	DRHOTON
Reviewer	ERANDOLPH
Manager	CKRETOVIC


Hard copy is intended to be 24"x36" when plotted. Scale(s) indicated and graphic quality may not be accurate for any other size.

PROJECT NO.
2500281

SHEET NO.

C305

©Copyright 2026
All Rights Reserved

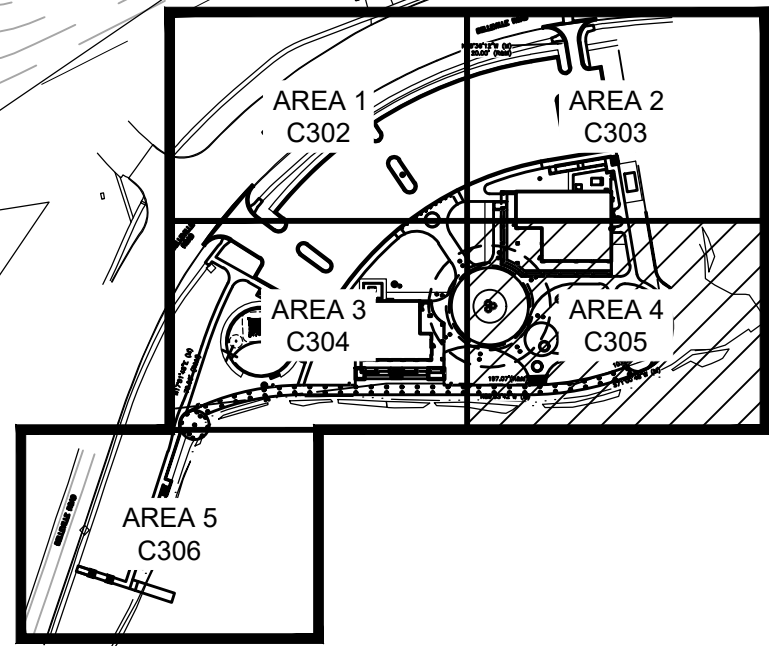

ENLARGED
GRADING KEYPLAN
SCALE: NONE

BENCH MARKS

BENCH MARK 201 ELEVATION: 668.38
MAG NAIL IN SOUTHEASTERLY CORNER OF CONCRETE PAD ON SOUTHERLY SIDE OF BELLEVILLE ROAD, DIRECTLY ACROSS FROM QUIRK ROAD (TO BE REMOVED)

BENCH MARK 202 ELEVATION: 679.17
ARROW ON HYDRANT ON SOUTHERLY SIDE OF BELLEVILLE ROAD 400' EAST OF INTERSECTION OF BELLEVILLE ROAD AND QUIRK ROAD


NOTES

- SEE C301.


SYMBOL LEGEND

-725-	EXISTING MAJOR CONTOUR
-724-	EXISTING MINOR CONTOUR
-725-	PROPOSED MAJOR CONTOUR
-724-	PROPOSED MINOR CONTOUR
724.50 XX	SPOT ELEVATION
EM	EDGE OF METAL
EW	EDGE OF WALK
FF	FINISH FLOOR
GR	GRADE ELEVATION
GU	GUTTER
HP	HIGH POINT
TC	TOP OF CURB
TP	TOP OF PAVEMENT
TW	TOP OF WALL


PLT: INFO: Z:\2025\2500281\CAD\C307_2500281.DWG LAYOUT: C307 DATE: 10/27/2026 TIME: 10:57:34 AM USER: DRHOTON

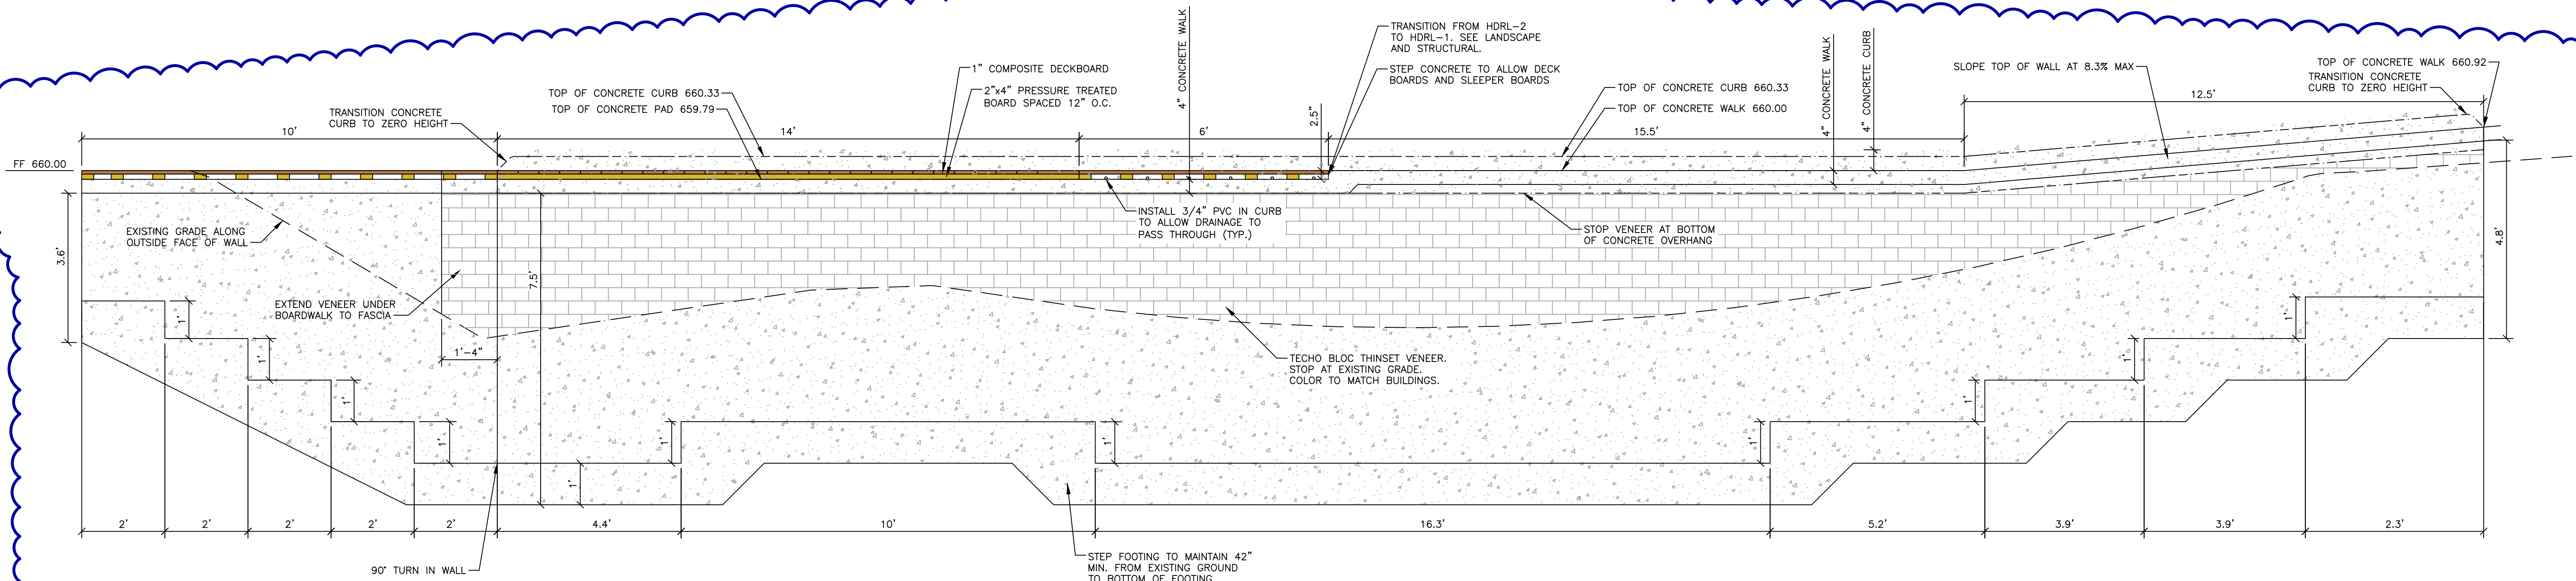


EAST TERMINUS RETAINING WALL ELEVATION
NO SCALE

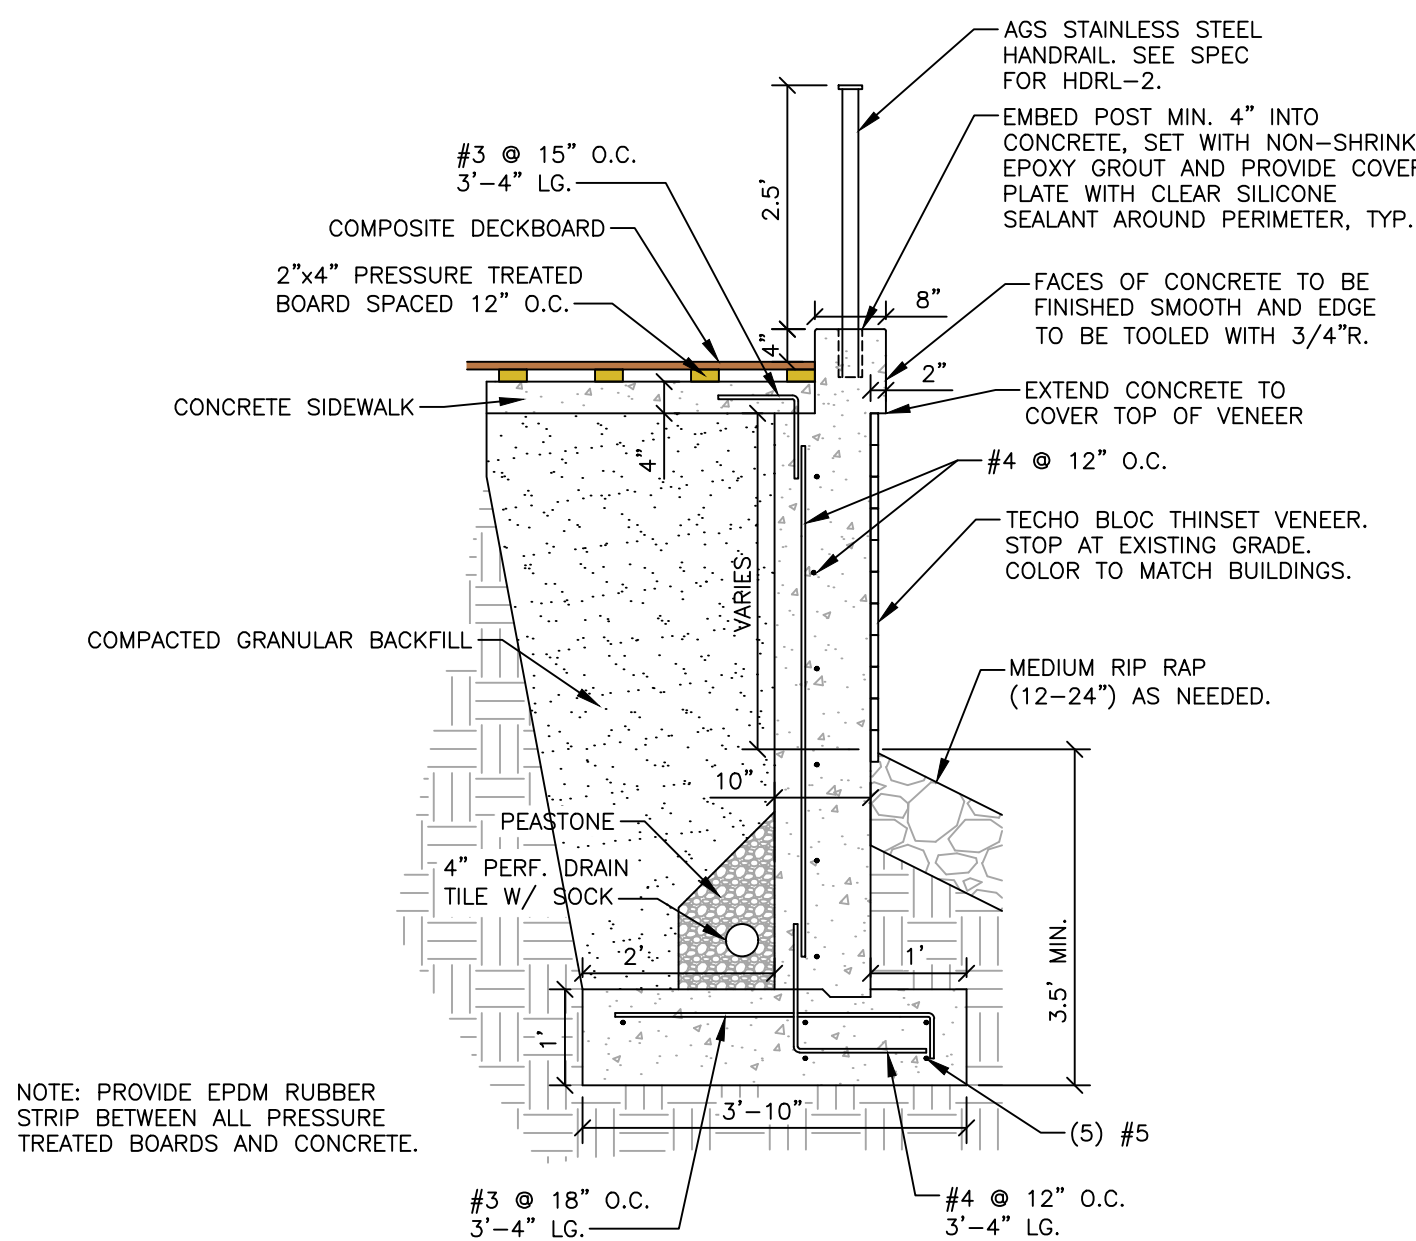


4 EAST TERMINUS RETAINING WALL SECTION
NO SCALE

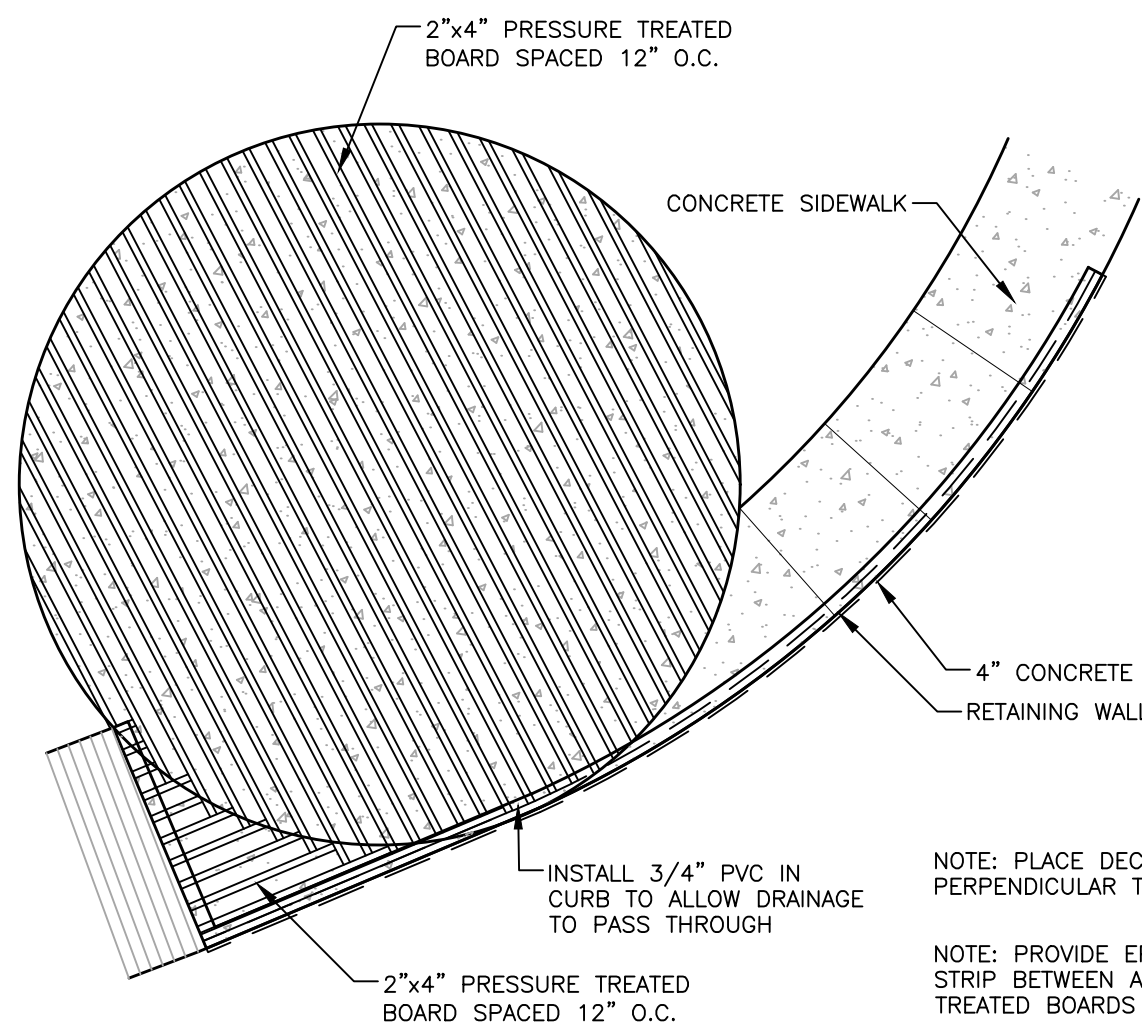


EAST TERMINUS PLAN VIEW
NO SCALE

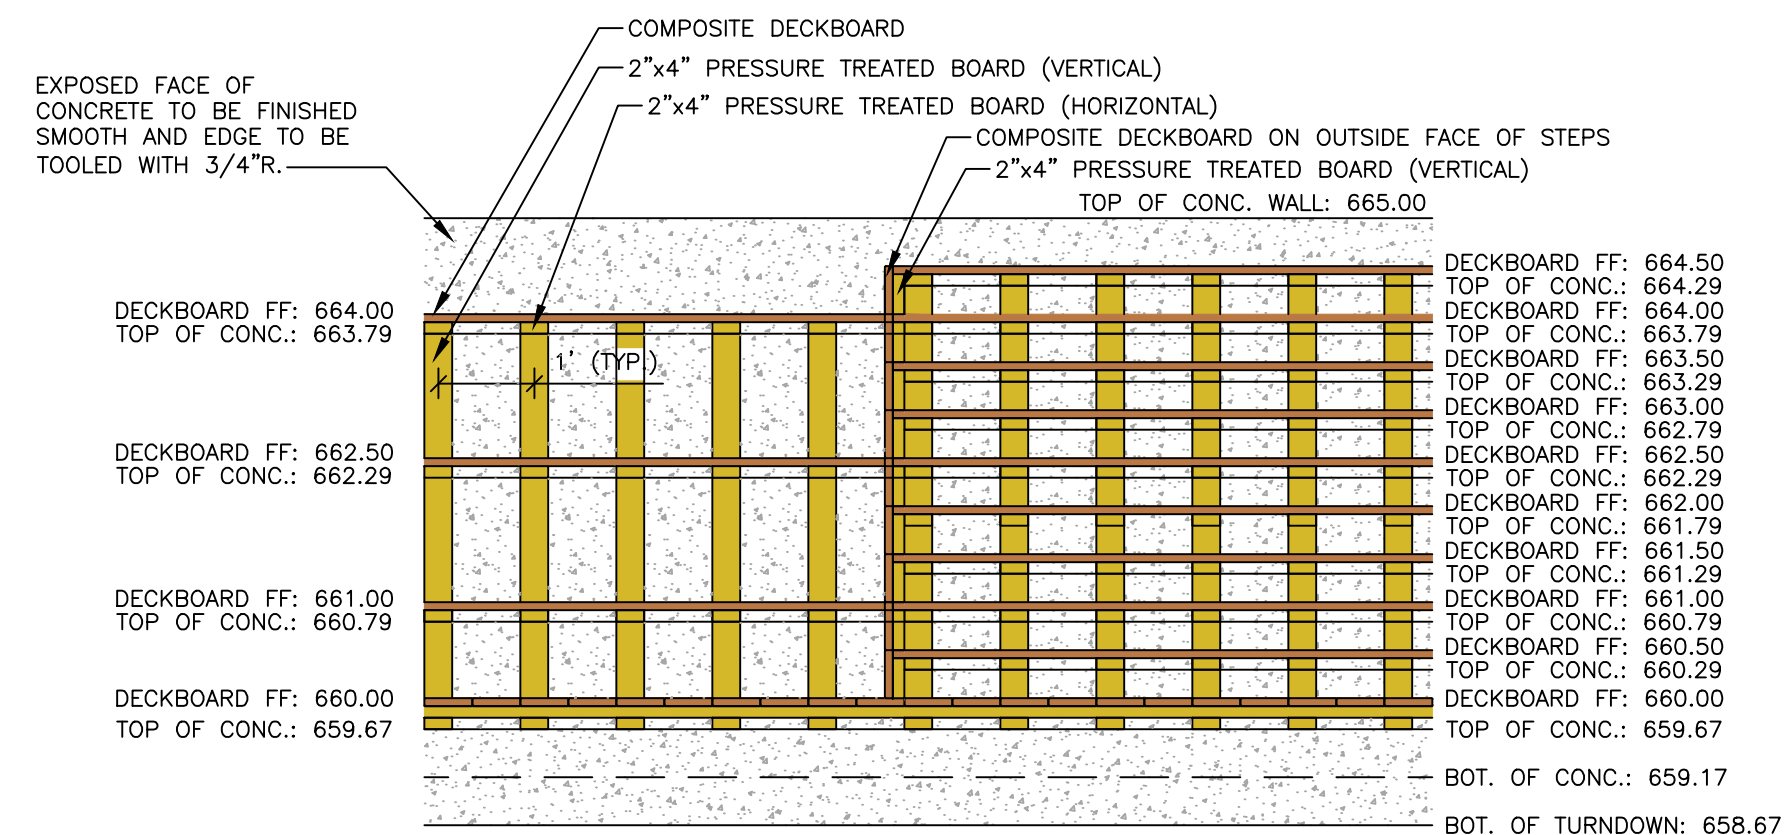


LAKE HOUSE TIERED SEATING/STEP ELEVATION
NO SCALE

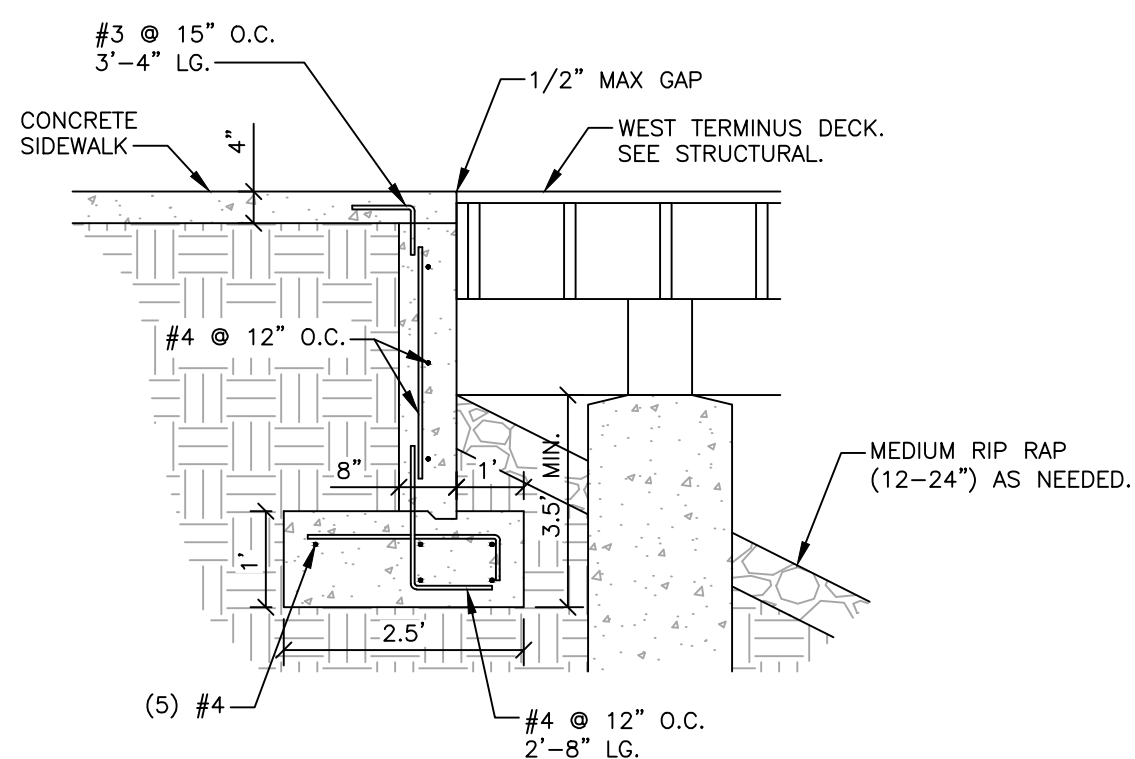

3 BOARDWALK/SIDEWALK JUNCTION RETAINING WALL
NO SCALE

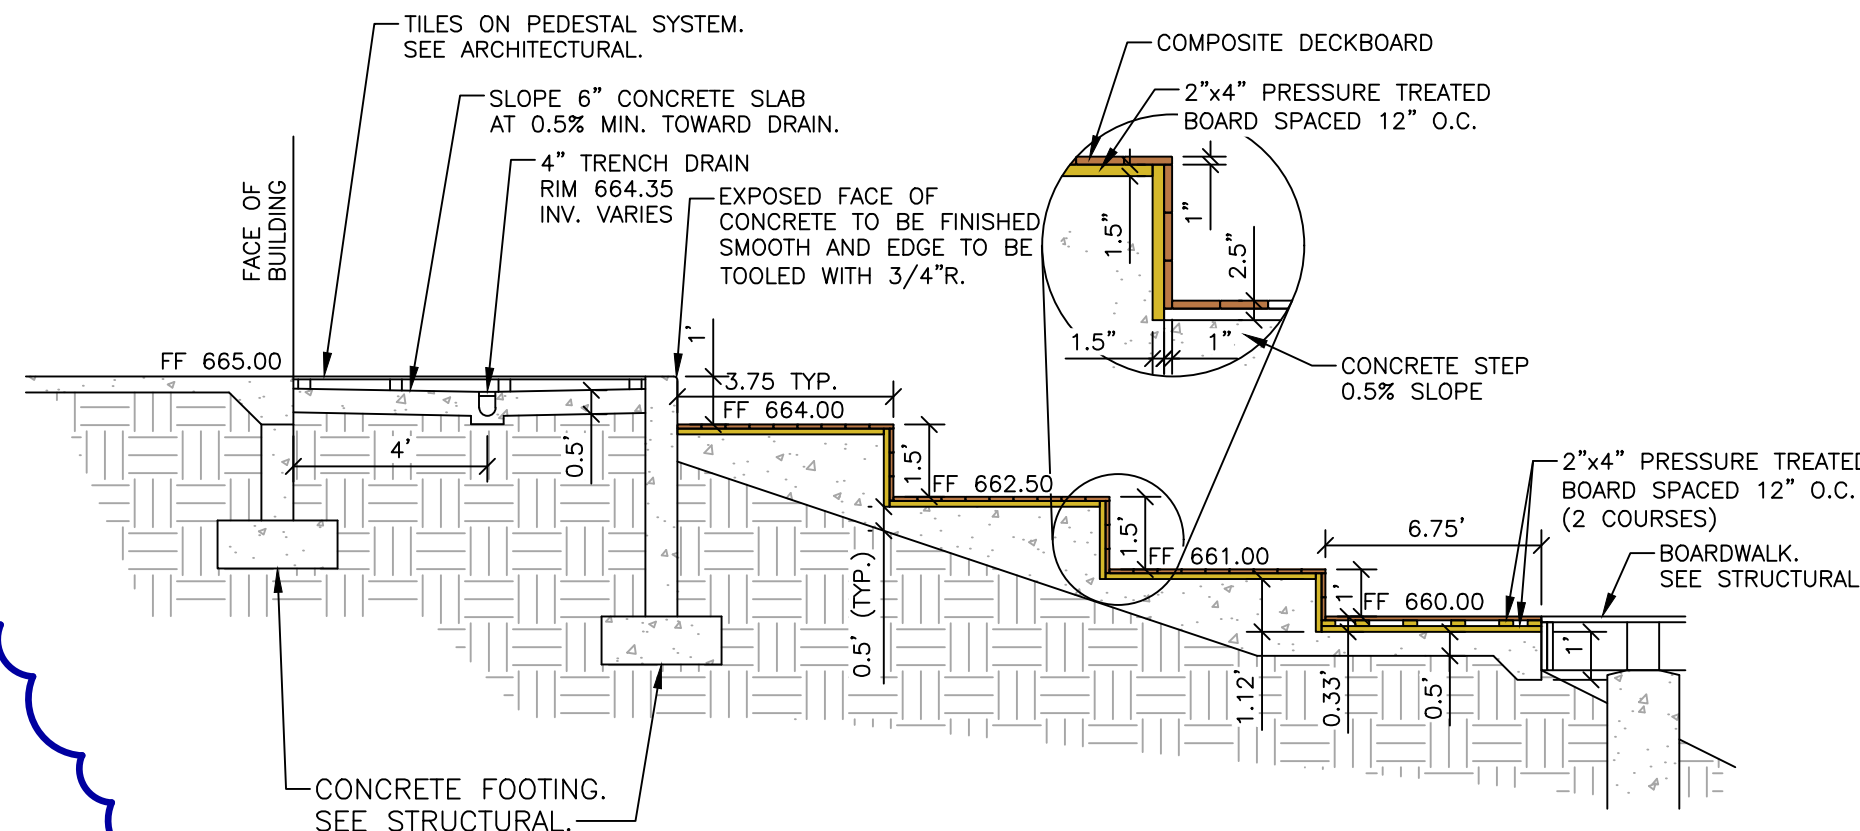

2 LAKE HOUSE TIERED SEATING SECTION
NO SCALE

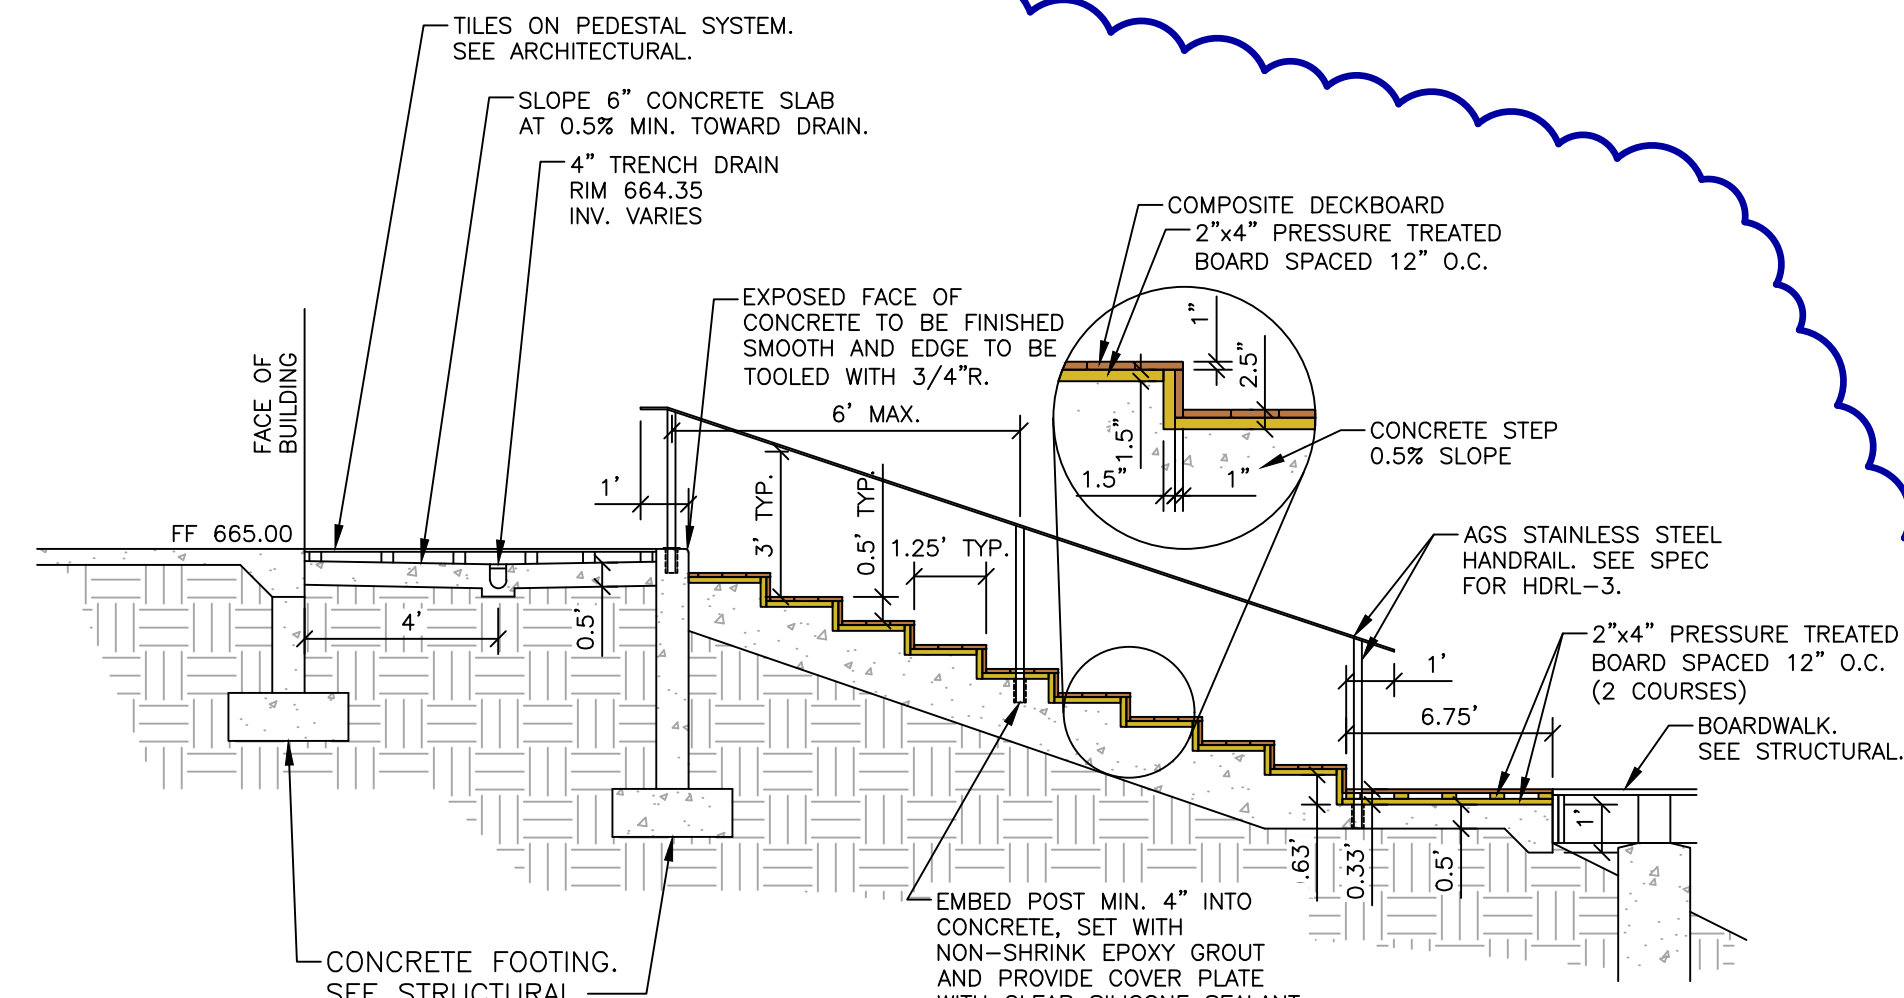

1 LAKE HOUSE STAIR SECTION
NO SCALE

Van Buren Charter Township

Van Buren Township, MI

The Lakeside Park

REVISIONS		
10/27/2026	A2	ADDENDUM NO. 2

10/12/2026 BIDS & PERMITS	
09/21/2026	CD PEER REVIEW
09/08/2026	CD TEAM REVIEW
08/10/2026	CD 50% PROGRESS
06/22/2026	DD OWNER REVIEW
06/15/2026	DD PEER REVIEW
06/08/2026	DD 90% PROGRESS
05/18/2026	DD 50% PROGRESS
02/23/2026	SD OWNER REVIEW
02/13/2026	SD PEER REVIEW
02/09/2026	SD PROGRESS REVIEW

Drawn By	ARAMIREZ
Designer	DRHOTON
Reviewer	ERANDOLPH
Manager	OKRETOVIC



Hard copy is intended to be 24"x36" when plotted. Scale(s) indicated and graphic quality may not be accurate for any other size.

PROJECT NO.
2500281

SHEET NO.

C307

PLT: INFO: Z:\2025\2500281\CAD\C401_2500281.DWG LAYOUT: C401 DATE: 10/27/2026 TIME: 11:20:59 AM USER: DRHOTON

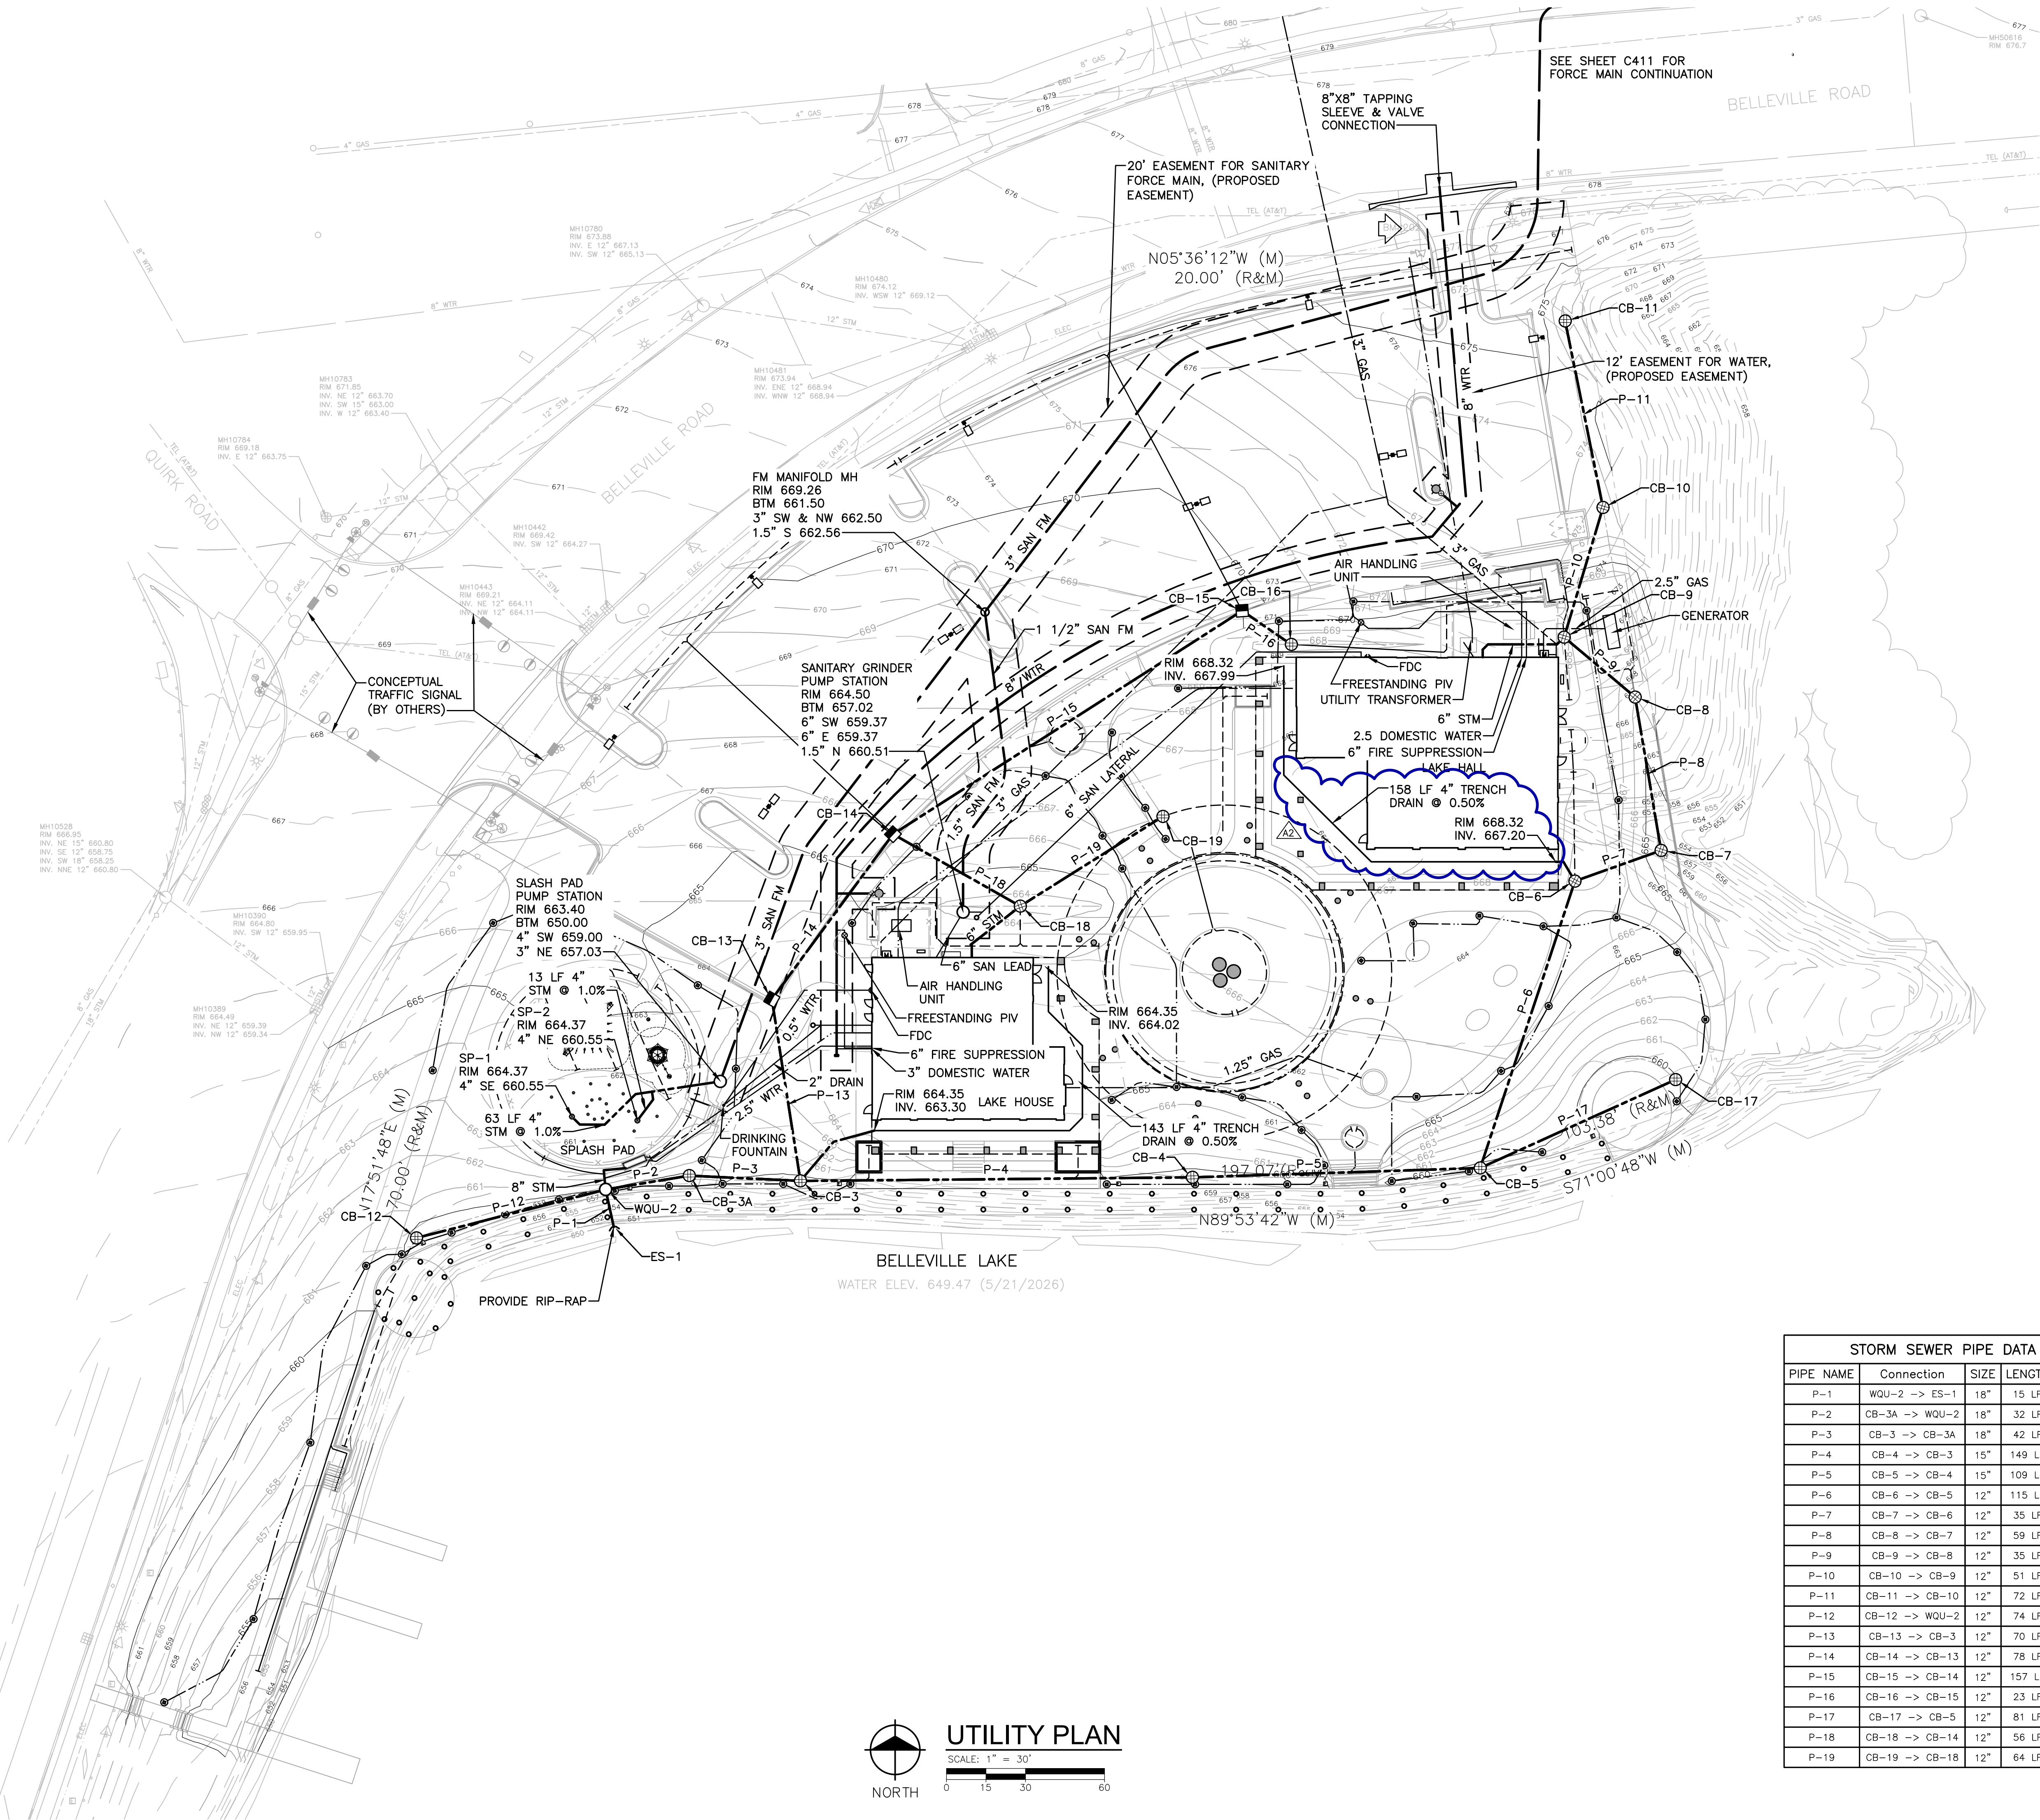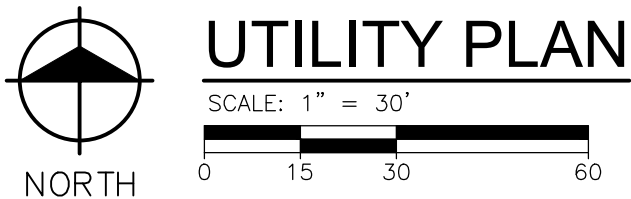

BENCH MARKS

BENCH MARK 201 ELEVATION: 668.38
MAG NAIL IN SOUTHEASTERLY CORNER OF CONCRETE PAD ON SOUTHERLY SIDE OF BELLEVILLE ROAD, DIRECTLY ACROSS FROM QUIRK ROAD (TO BE REMOVED)

BENCH MARK 202 ELEVATION: 679.17
ARROW ON HYDRANT ON SOUTHERLY SIDE OF BELLEVILLE ROAD 400' EAST OF INTERSECTION OF BELLEVILLE ROAD AND QUIRK ROAD

SYMBOL LEGEND

- 8" SAN SANITARY SEWER & MANHOLE
- 4" FM SANITARY FORCE MAIN
- WYE & LEAD
- RISER & LEAD
- STANDARD SEWER CLEANOUT
- 12" STM STORM SEWER & MANHOLE
- CATCH BASIN
- 8" WTR WATER MAIN
- GAS MAIN
- ELECTRIC
- TELEPHONE/FIBER OPTIC
- UNDERDRAIN
- IRRIGATION SLEEVE. SEE LANDSCAPE.

NOTES

- EXISTING UTILITIES LOCATIONS SHOWN ARE APPROXIMATE.
- VERIFY THE HORIZONTAL AND VERTICAL LOCATION OF EXISTING UTILITIES PRIOR TO EXCAVATION WHERE NECESSARY.
- PROTECT AND MAINTAIN SERVICE OF OTHER UTILITIES AT CROSSINGS.
- DO NOT CONNECT ROOF DRAINS, FOUNDATION DRAINS, AND OTHER CLEAN WATER SERVICES TO THE SANITARY SEWER.
- END SECTIONS ARE INCLUDED IN PIPE LENGTHS SHOWN.
- PROVIDE RIPRAP AT ALL END SECTIONS UNLESS OTHERWISE NOTED.
- PROVIDE AND MAINTAIN INLET FILTERS AT ALL CATCH BASIN INLETS, DURING CONSTRUCTION.
- WATER MAIN TO HAVE A MINIMUM OF 6 FEET OF COVER.
- FIRE HYDRANTS LOCATED IN CURB ISLAND OR GREEN SPACE SHALL BE LOCATED 5' FROM BACK OF CURB OR EDGE OF PAVEMENT (TYP.).
- PROVIDE A MINIMUM OF EIGHTEEN (18) INCHES OF VERTICAL SEPARATION AND TEN (10) FEET OF HORIZONTAL SEPARATION BETWEEN THE WATER MAIN AND ALL SANITARY AND STORM SEWERS.
- FACE NOZZLES OF SITE FIRE HYDRANTS TOWARD BUILDING.
- ADJUST ALL CASTINGS TO FINISH GRADES.
- PIPE LENGTHS ARE TO CENTER OF STRUCTURES UNLESS NOTED OTHERWISE. ALL PIPE LENGTHS ARE FOR THE CONVENIENCE OF THE CONTRACTOR.
- UTILITY ELEVATIONS INDICATED REPRESENT INVERT ELEVATIONS UNLESS OTHERWISE NOTED.

STORM SEWER STRUCTURES

STRUCTURE	RIM	SIZE	INVERT	ELEVATION
ES-1	651.61	18" N.		650.00
WQU-2	660.00	48"	18" S. 12" W. 18" E.	650.27 650.38 651.77
CB-3A	659.65	48"	18" W. 18" E.	652.76 652.76
CB-3	659.65	48"	12" N. 18" W. 15" E.	655.90 654.06 654.26
CB-4	659.40	48"	15" E. 15" W.	655.27 654.60
CB-5	659.55	48"	12" N. 15" W. 12" NE.	655.80 655.52 655.77
CB-6	666.27	48"	12" E. 12" S.	659.79 659.79
CB-7	663.70	48"	12" N. 12" W.	660.70 660.70
CB-8	666.00	48"	12" NW. 12" S.	662.25 662.25
CB-9	667.75	48"	12" N. 12" SE. 6" SW.	664.00 662.80 663.20
CB-10	673.10	48"	12" S. 12" N.	665.58 668.63
CB-11	672.60	48"	12" S.	668.85
CB-12	659.25	48"	12" E.	650.61
CB-13	663.32	48"	12" NE. 12" SW. 12" SE.	662.20 659.04 659.14
CB-15	669.49	48"	12" SE. 12" SW.	663.69 663.59
CB-16	667.51	48"	12" NW.	663.76
CB-17	659.77	48"	12" SW.	656.02
CB-18	663.50	48"	12" NE. 6" SW. 12" NW.	659.75 659.71 659.31
CB-19	666.00	48"	12" SW.	661.73

STORM SEWER PIPE DATA

PIPE NAME	Connection	SIZE	LENGTH	SLOPE
P-1	WQU-2 -> ES-1	18"	15 LF	1.80%
P-2	CB-3A -> WQU-2	18"	32 LF	3.07%
P-3	CB-3 -> CB-3A	18"	42 LF	3.08%
P-4	CB-4 -> CB-3	15"	149 LF	0.23%
P-5	CB-5 -> CB-4	15"	109 LF	0.23%
P-6	CB-6 -> CB-5	12"	115 LF	3.47%
P-7	CB-7 -> CB-6	12"	35 LF	2.63%
P-8	CB-8 -> CB-7	12"	59 LF	2.63%
P-9	CB-9 -> CB-8	12"	35 LF	1.56%
P-10	CB-10 -> CB-9	12"	51 LF	3.09%
P-11	CB-11 -> CB-10	12"	72 LF	0.31%
P-12	CB-12 -> WQU-2	12"	74 LF	0.31%
P-13	CB-13 -> CB-3	12"	70 LF	3.10%
P-14	CB-14 -> CB-13	12"	78 LF	0.31%
P-15	CB-15 -> CB-14	12"	157 LF	0.88%
P-16	CB-16 -> CB-15	12"	23 LF	0.31%
P-17	CB-17 -> CB-5	12"	81 LF	0.31%
P-18	CB-18 -> CB-14	12"	56 LF	0.31%
P-19	CB-19 -> CB-18	12"	64 LF	3.10%

Van Buren Charter Township

Van Buren Township, MI

The Lakeside Park

REVISONS		
10/27/2026	A2	ADDENDUM NO. 2

10/12/2026	BIDS & PERMITS
09/21/2026	CD PEER REVIEW
09/08/2026	CD TEAM REVIEW
08/10/2026	CD 50% PROGRESS
06/22/2026	DD OWNER REVIEW
06/15/2026	DD PEER REVIEW
06/08/2026	DD 90% PROGRESS
05/18/2026	DD 50% PROGRESS
02/23/2026	SD OWNER REVIEW
02/13/2026	SD PEER REVIEW
02/09/2026	SD PROGRESS REVIEW

Drawn By	DRHOTON
Designer	DRHOTON
Reviewer	ERANDOLPH
Manager	OKRETOVIC

Hard copy is intended to be 24"x36" when plotted. Scale(s) indicated and graphic quality may not be accurate for any other size.

PROJECT NO.
2500281

SHEET NO.


C401

©Copyright 2026
All Rights Reserved




R3-2

NO LEFT TURN SIGN
NO SCALE

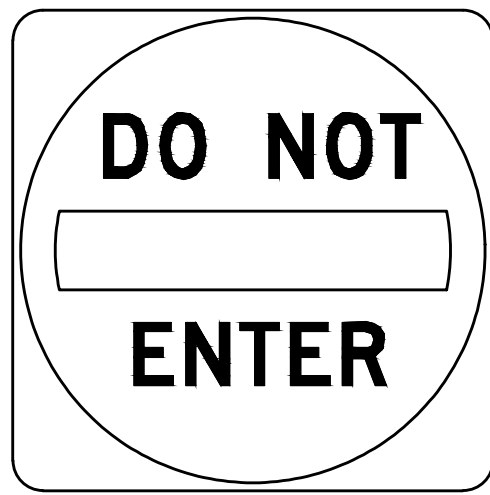


R5-1


DO NOT ENTER SIGN
NO SCALE

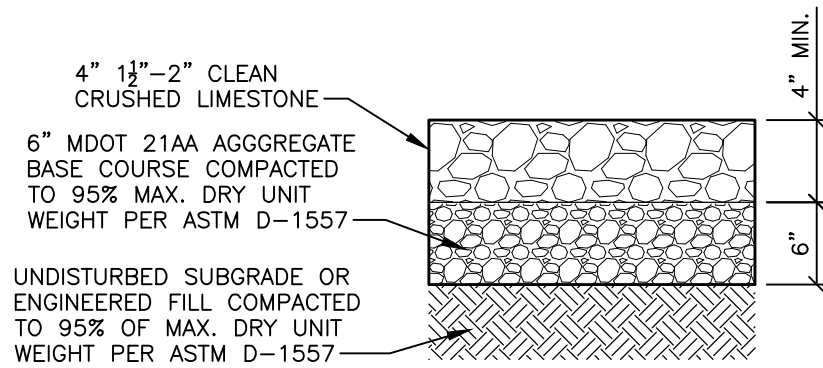


GRAVEL PAVEMENT DETAIL

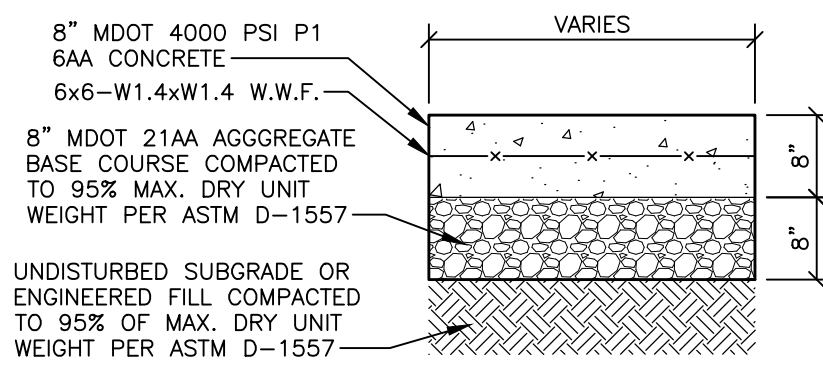


HEAVY DUTY CONCRETE DETAIL

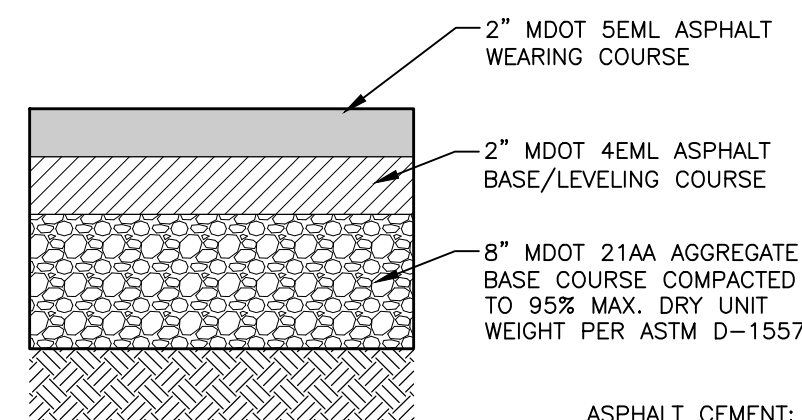


STANDARD DUTY ASPHALT DETAIL
NO SCALE

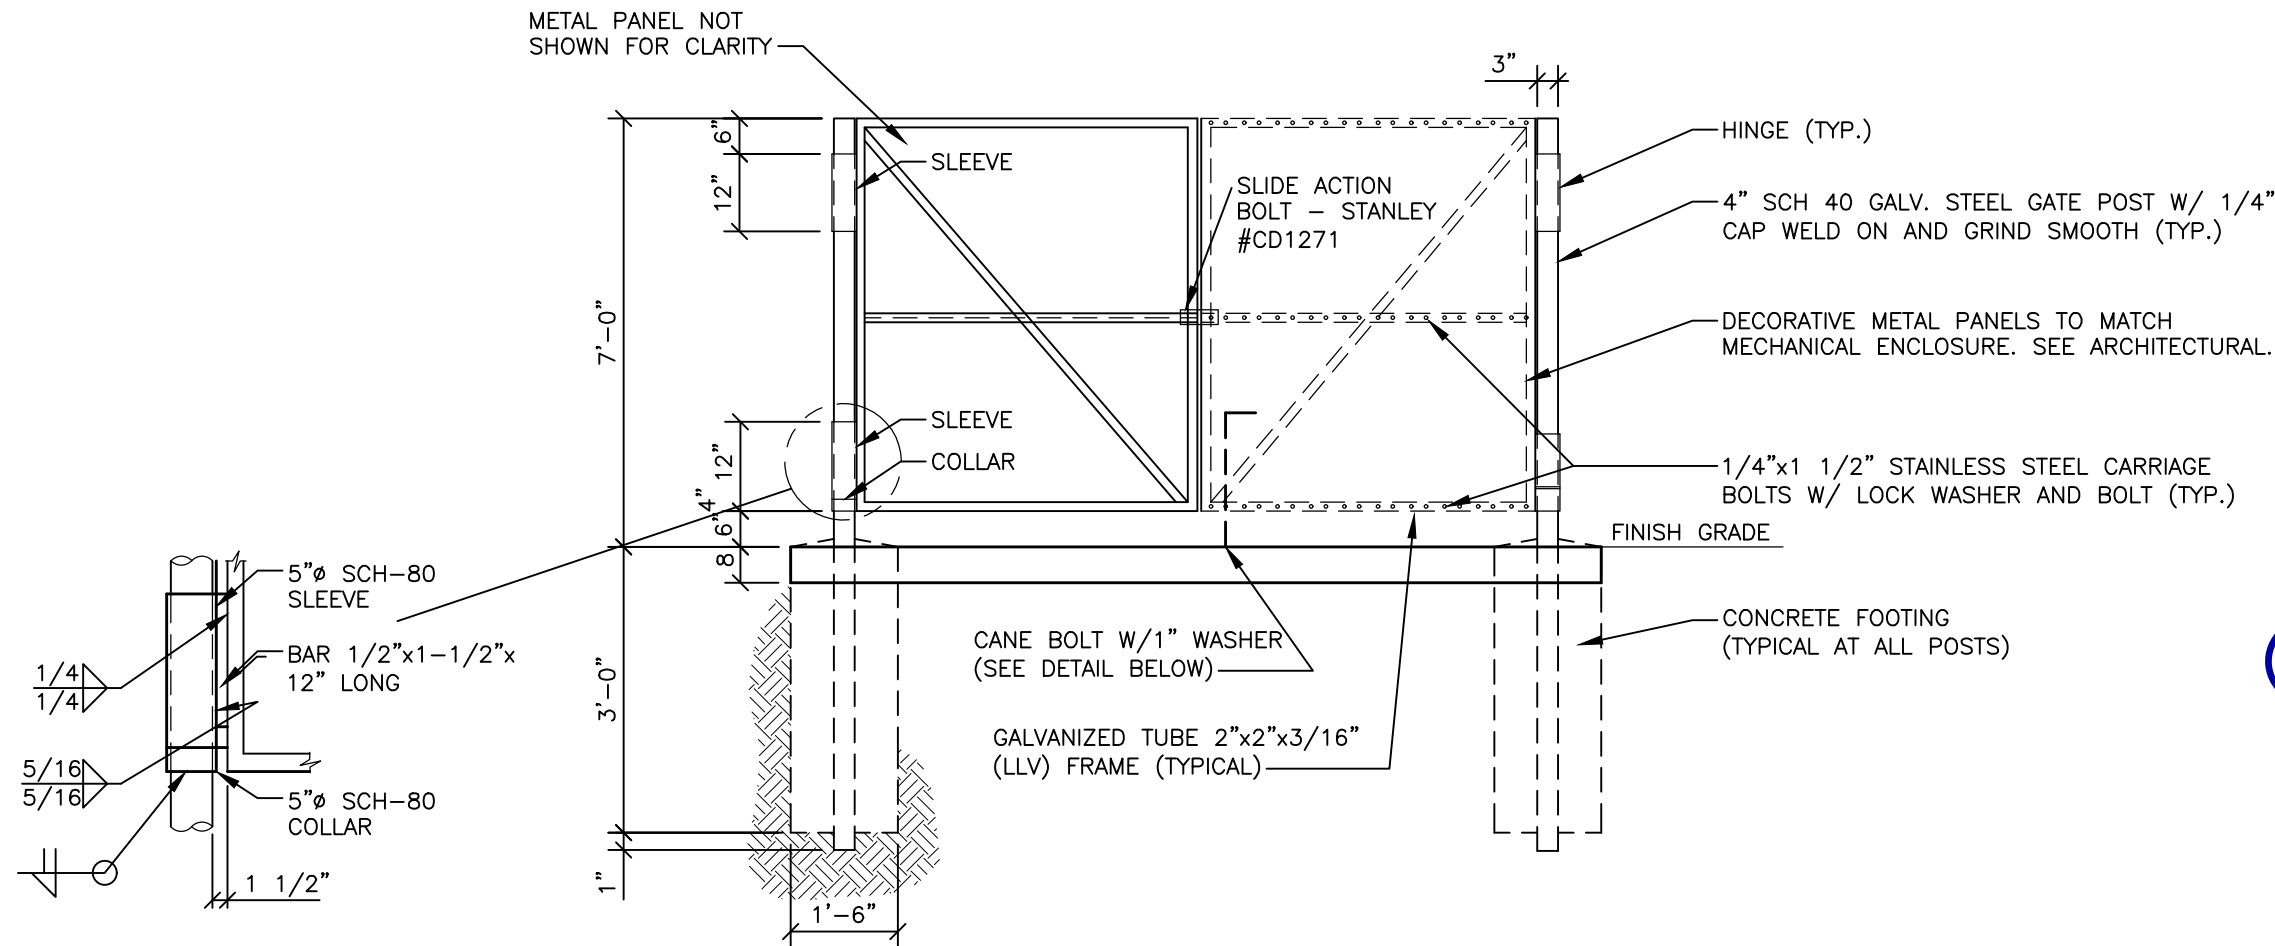


DUMPSTER GATE ELEVATION
NO SCALE

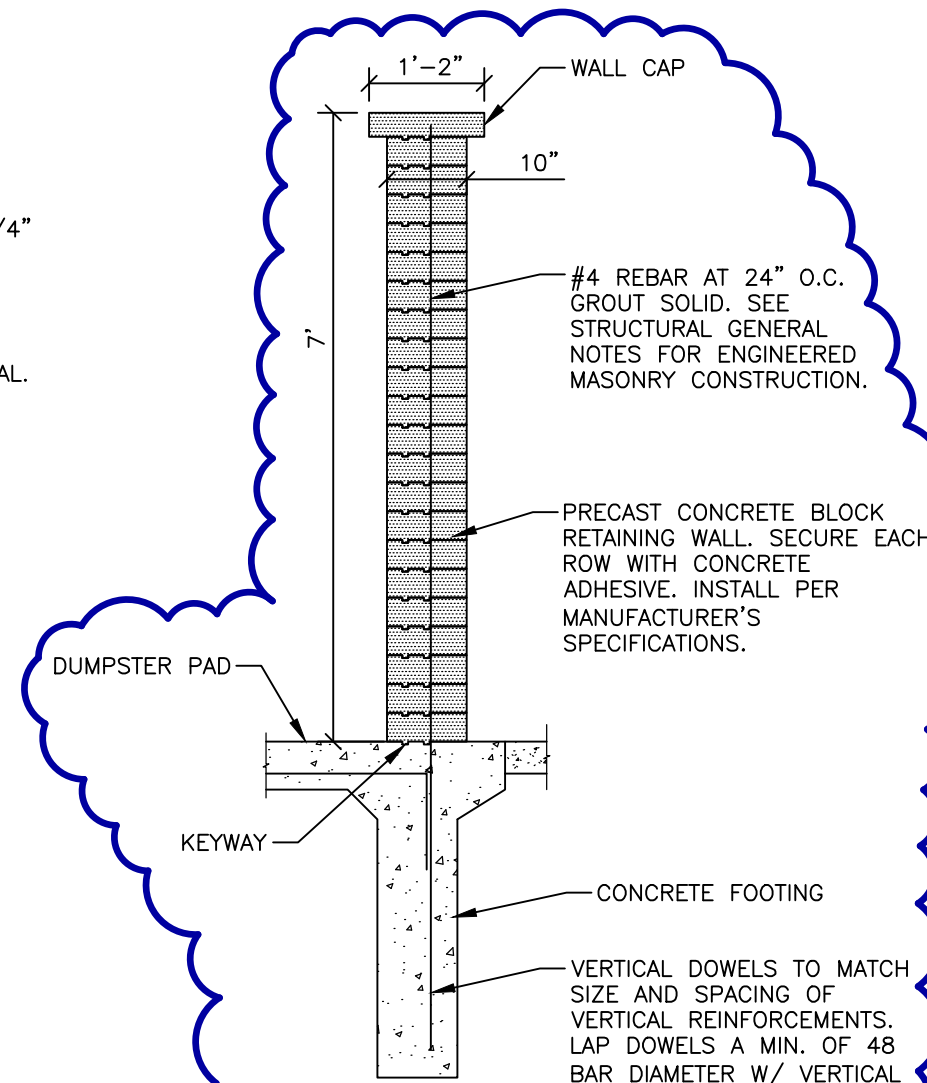


DUMPSTER WALL DETAIL
NO SCALE

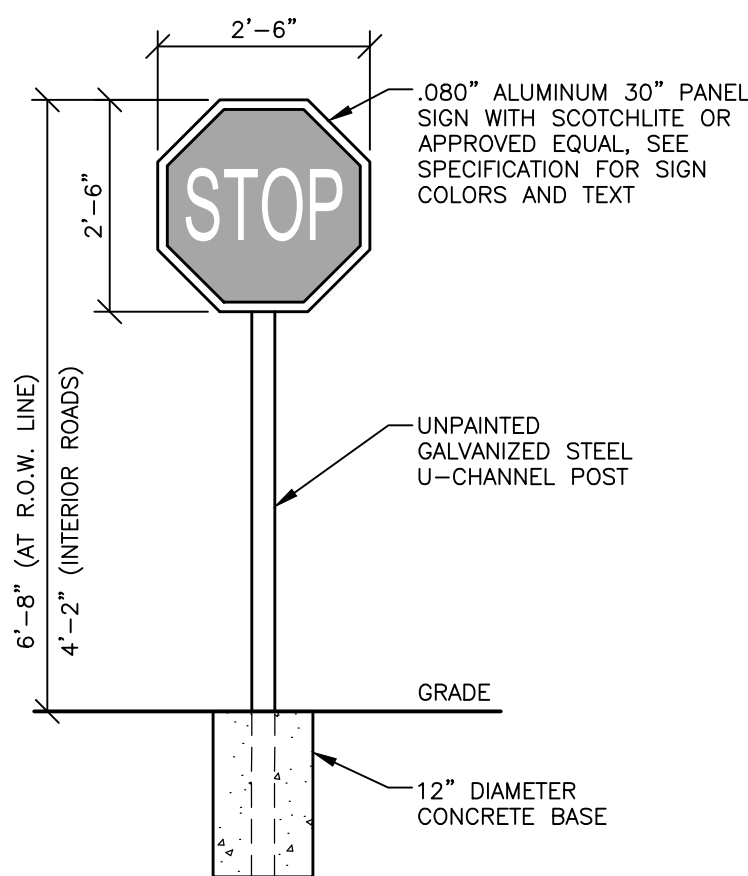


STOP SIGN DETAIL
NO SCALE

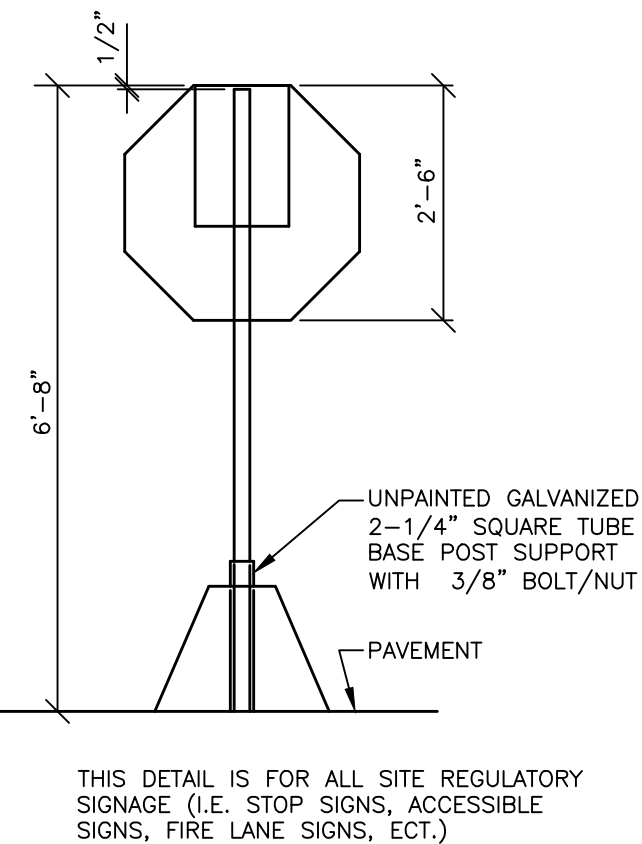


THIS DETAIL IS FOR ALL SITE REGULATORY SIGNAGE (I.E. STOP SIGNS, ACCESSIBLE SIGNS, FIRE LANE SIGNS, ECT.)

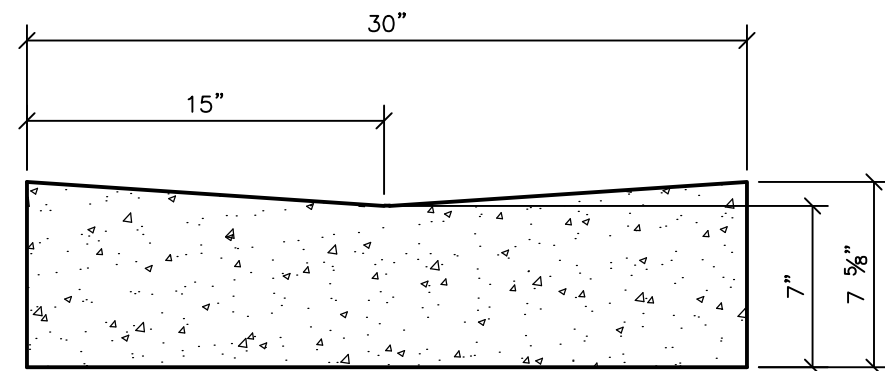


STANDARD GUTTER PAN
NO SCALE

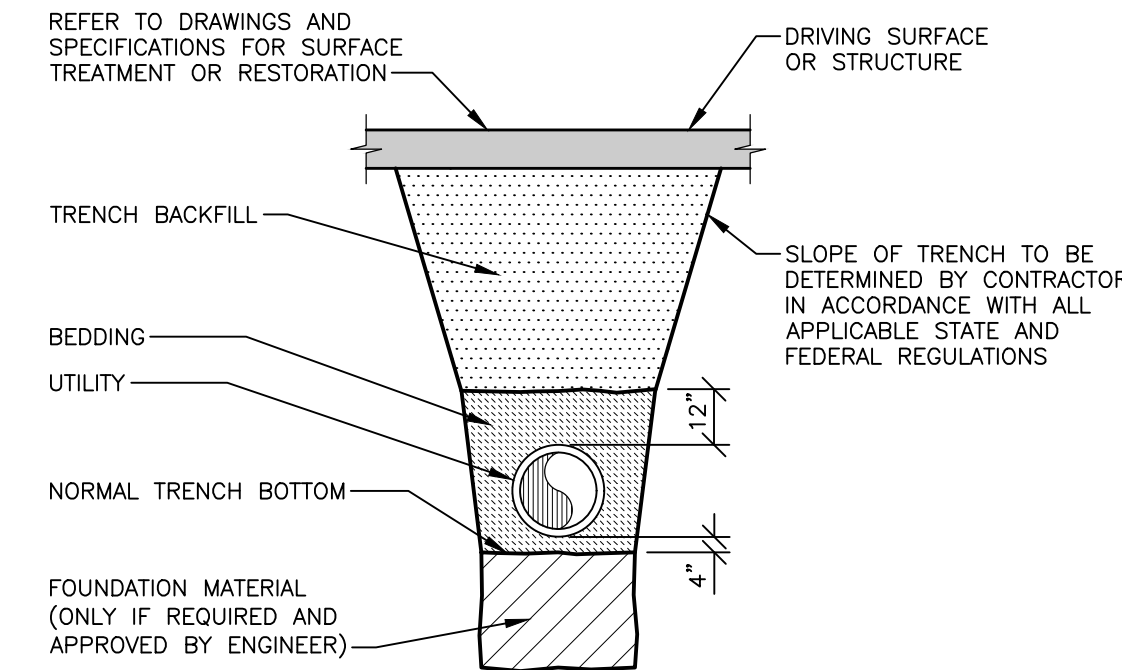


TRENCH BELOW DRIVING SURFACE OR STRUCTURE
NO SCALE

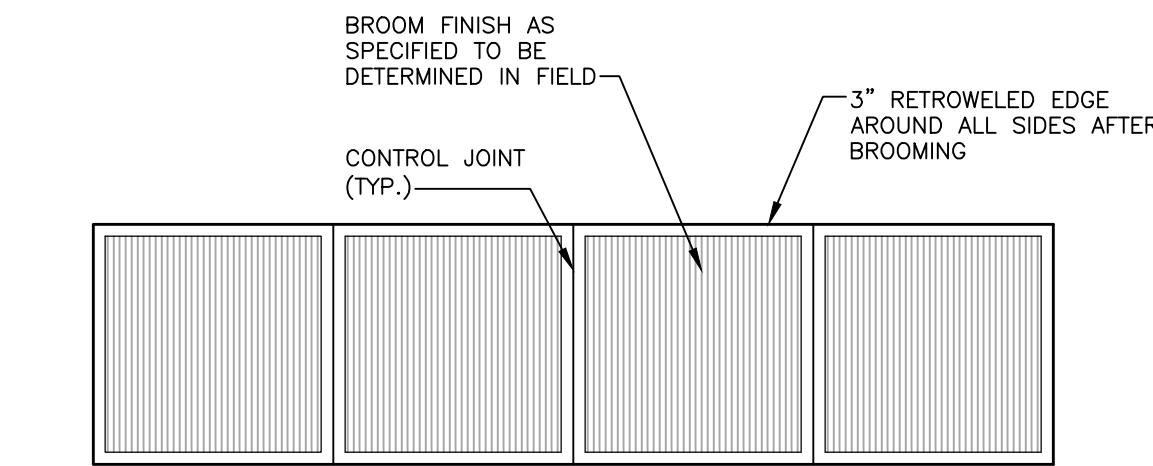


BROOM FINISH SIDEWALK DETAIL
NO SCALE

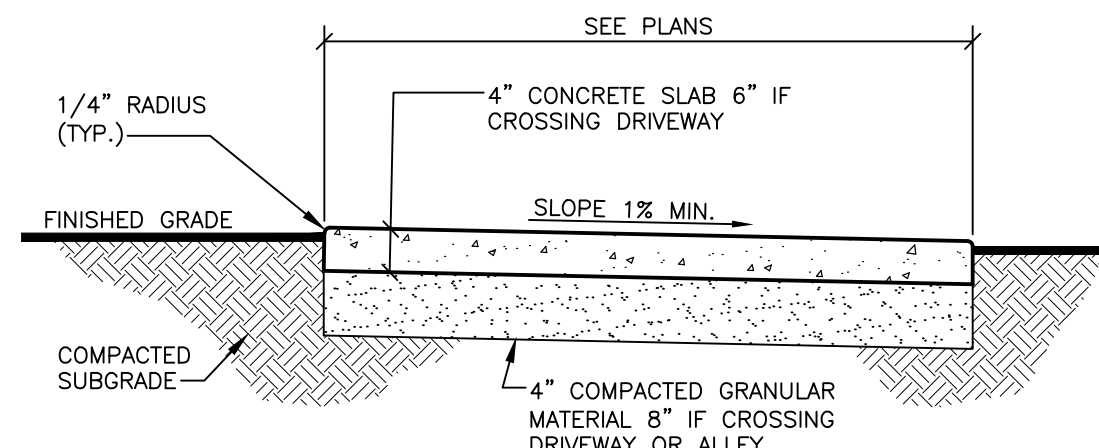


SIDEWALK DETAIL
NO SCALE

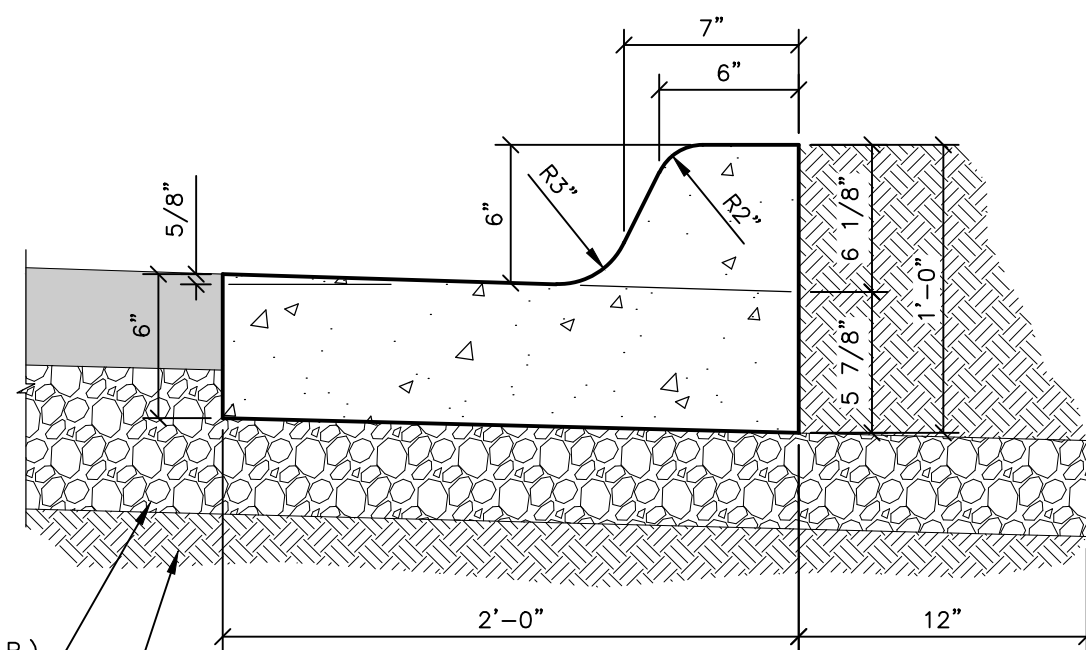

STANDARD CROWN CURB & GUTTER
NO SCALE

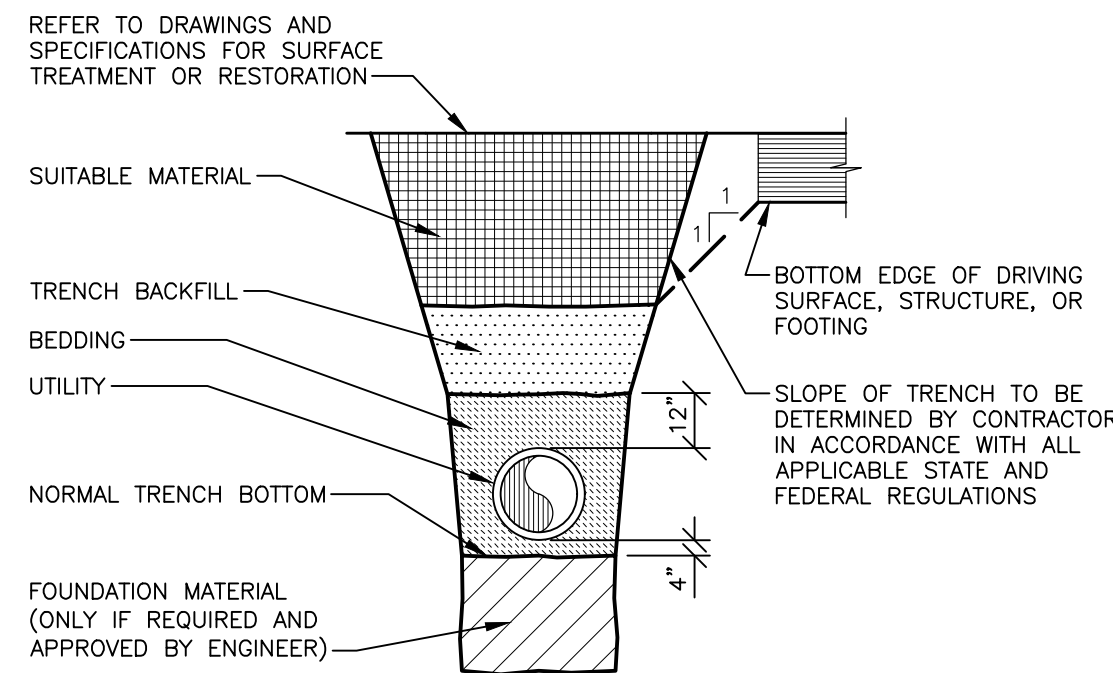

TRENCH ADJACENT TO DRIVING SURFACE OR STRUCTURE
NO SCALE

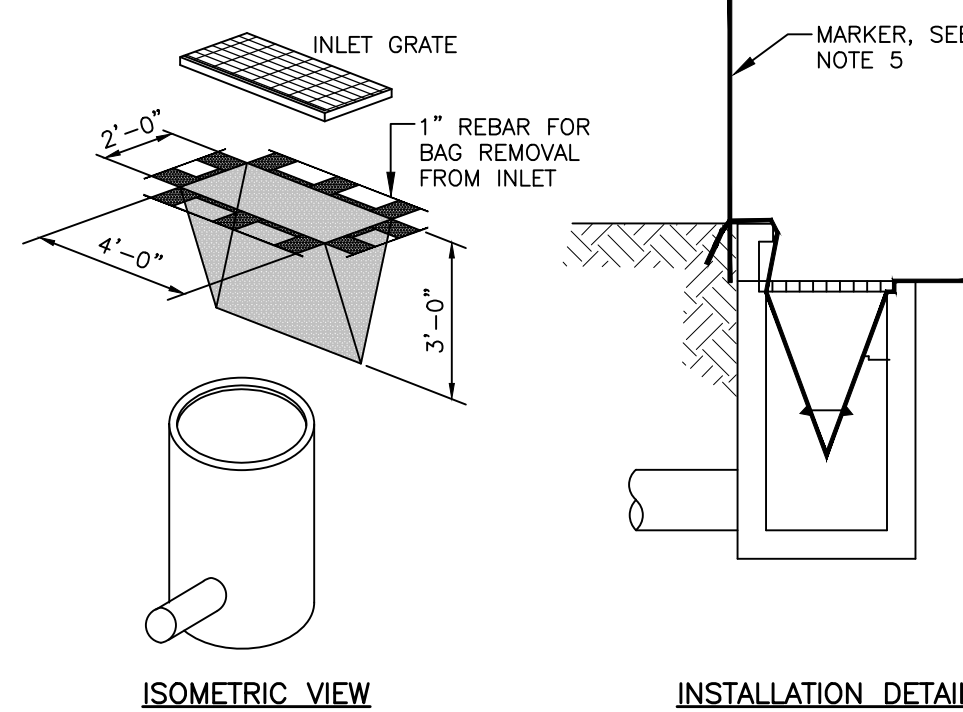

ISOMETRIC VIEW

INSTALLATION DETAIL

NOTES:

1. PLACE FILTER FABRIC BAG INSIDE THE INLET BENEATH THE GRATE.
2. REPLACE GRATE, WHICH WILL HOLD BAG IN PLACE.
3. ANCHOR FILTER BAG SO IT WILL NOT DROP INTO CATCH BASIN.
4. EXTEND FLAPS OF BAG BEYOND THE BAG. BURY IN SOIL IN EARTH AREAS.
5. IF CATCH BASIN IS IN A LOW DEPRESSION - MARK CB LOCATION WITH A MARKER TO ASSIST LOCATING CATCH BASIN IF FLOODING OCCURS.
6. INSPECT DROP INLET FILTERS ROUTINELY AND AFTER EACH RAIN EVENT.
7. REPLACE DAMAGED FILTER BAGS IMMEDIATELY.
8. CLEAN AND/OR REPLACE FILTER BAG WHEN 1/2 FULL. REPLACE CLOGGED FABRIC IMMEDIATELY.
9. VACUUM OUT CATCH BASIN SUMP IF FILTER BAG TEARS.
10. REMOVE ENTIRE PROTECTIVE MECHANISM WHEN UP GRADIENT AREAS ARE STABILIZED AND STREETS HAVE BEEN SWEEPED AND/OR DIRECTLY DETECTED BY ENGINEER/OWNER.

S58 INLET PROTECTION - FABRIC DROP
NO SCALE


INSTALLATION IN LAWN AREAS:
POSTS ARE TO BE LOCATED 5'-0" FROM EDGE OF CURB. BURY POST 3'-0" DEEP AND AS SHOWN ON DRAWINGS. MOUNT SIGN TO POST PER MANUFACTURER'S RECOMMENDATIONS.

PARKING - FIRE LANE SIGNS:
12"x18", NON-REFLECTIVE


ACCESSIBLE PARKING SIGNS:
REFLECTIVE 0.080 ALUMINUM WITH SCOTCHLITE, OR APPROVED EQUAL.

SUPPLEMENTAL VAN ACCESSIBLE SIGNS:
REFLECTIVE 0.080 ALUMINUM WITH SCOTCHLITE, OR APPROVED EQUAL.


WRONG WAY SIGNS:
30"x18" UV SCREEN PRINTED ALUMINUM

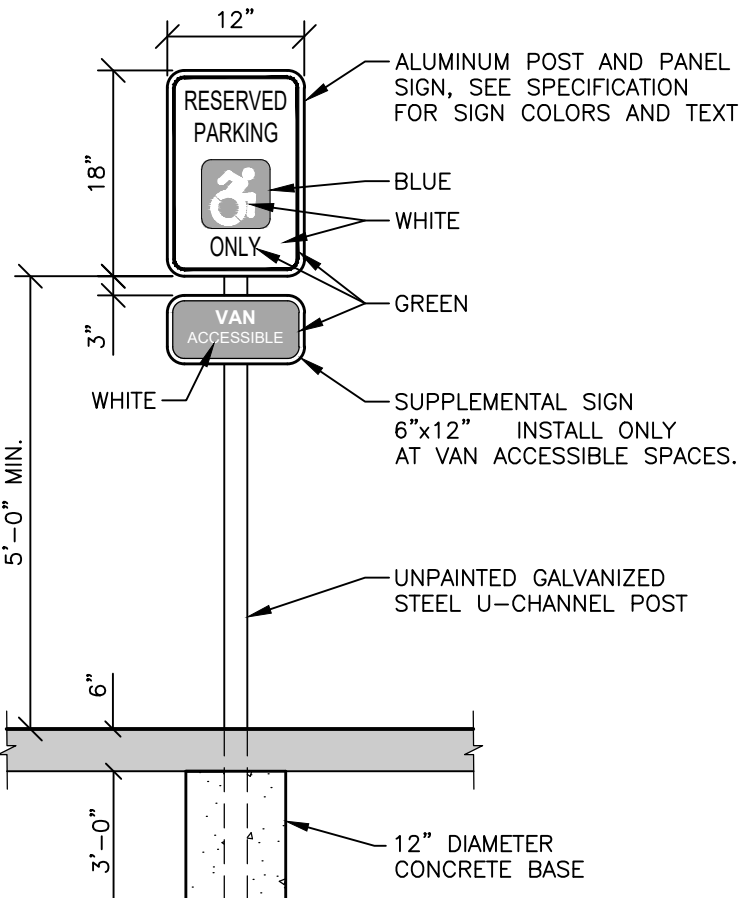


VAN ACCESSIBLE BARRIER FREE PARKING SIGN DETAIL
NO SCALE

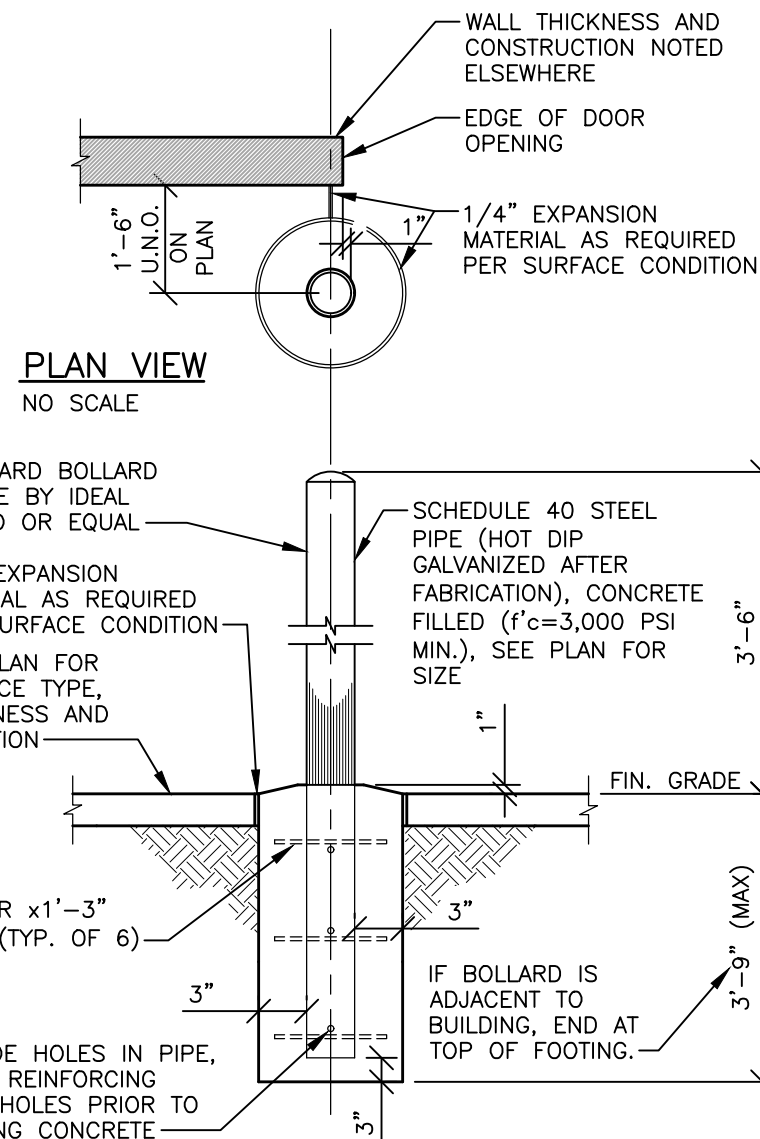

BOLLARD DETAIL
NO SCALE

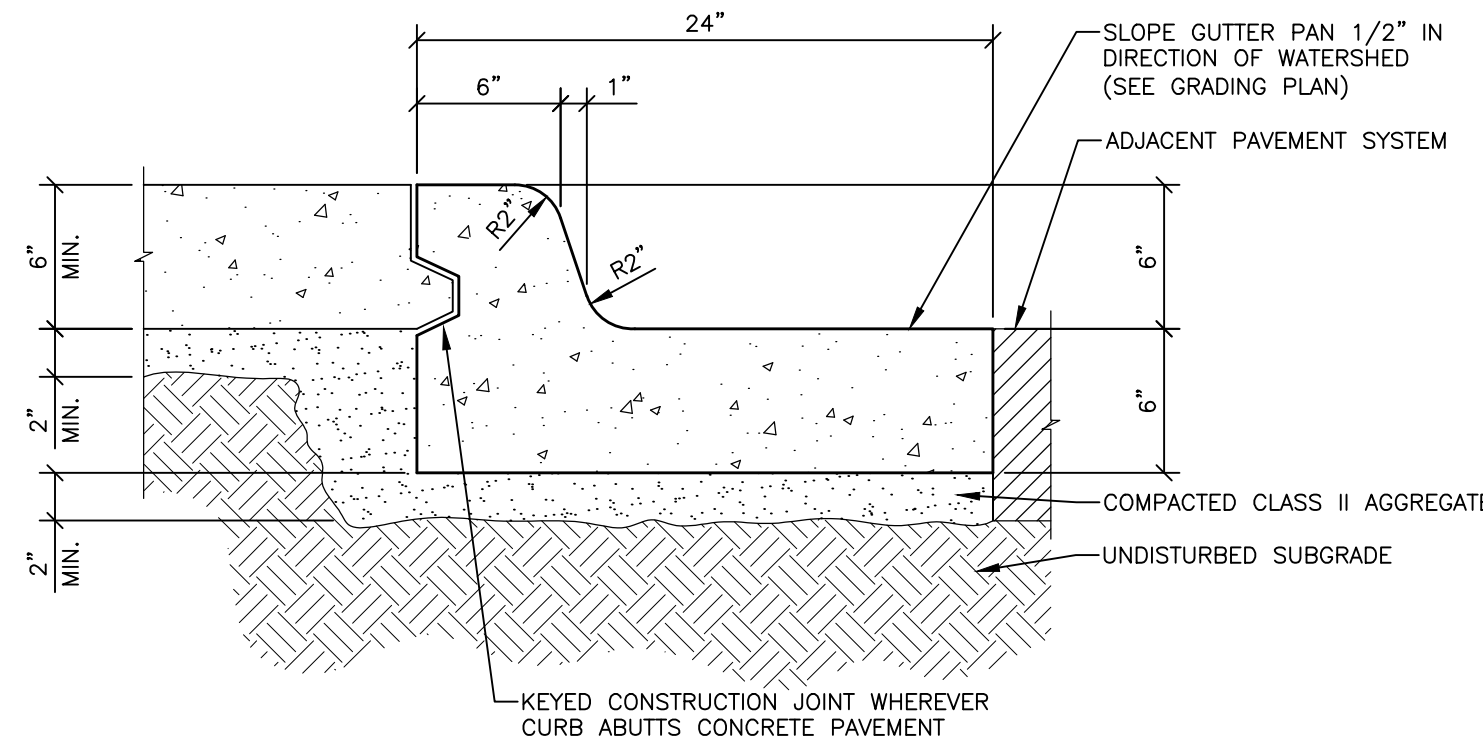

SIDEWALK KEYWAY SECTION
NO SCALE

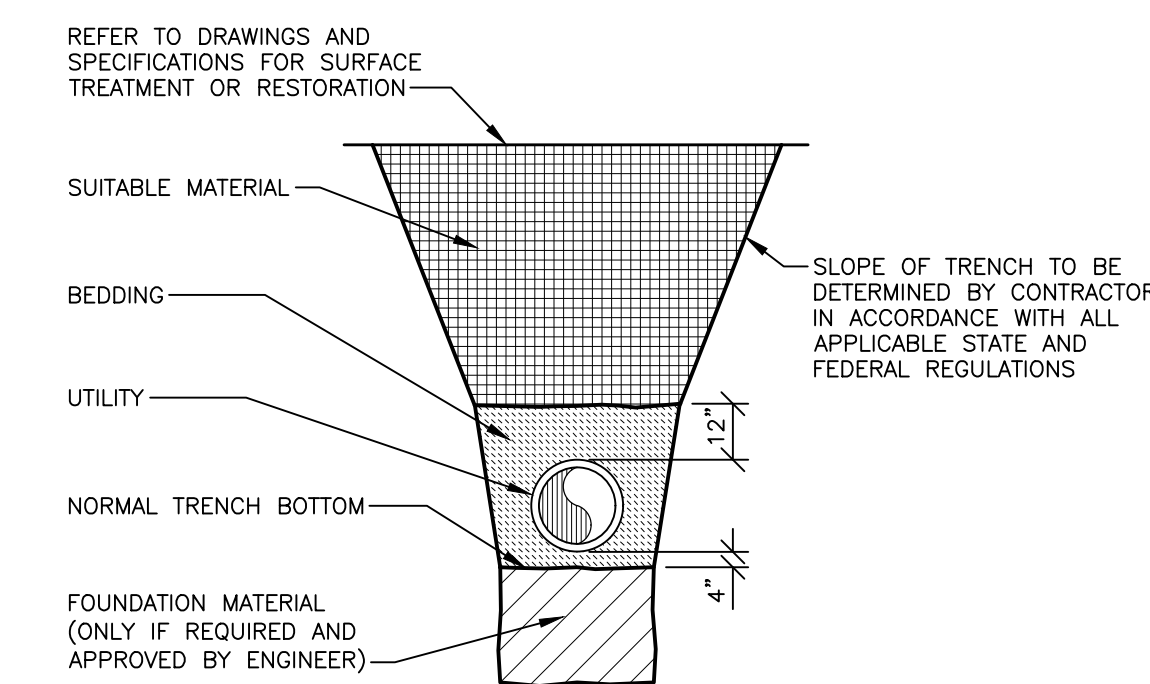

TRENCH NOT ADJACENT TO DRIVING SURFACE OR STRUCTURE
NO SCALE

Van Buren Charter Township

Van Buren Township, MI

The Lakeside Park

REVISIONS

10/27/2026	A2	ADDENDUM NO. 2
------------	----	----------------

10/12/2026	BIDS & PERMITS
09/21/2026	CD PEER REVIEW
09/09/2026	CD TEAM REVIEW
08/10/2026	CD 50% PROGRESS
06/22/2026	DD OWNER REVIEW
06/15/2026	DD PEER REVIEW
06/08/2026	DD 90% PROGRESS
05/18/2026	DD 50% PROGRESS
02/23/2026	SD OWNER REVIEW
02/13/2026	SD PEER REVIEW
02/09/2026	SD PROGRESS REVIEW

Drawn By	ARAMIREZ
Designer	DRHOTON
Reviewer	ERANDOLPH
Manager	OKRETOVIC

Hard copy is intended to be 24"x36" when plotted. Scale(s) indicated and graphic quality may not be accurate for any other size.

PROJECT NO.

2500281

SHEET NO.

C501

Pedestrian Paving Legend:


- 4" S.D. CONCRETE PAVEMENT, TYP. - REFER TO DETAILS
6" H.D. REINFORCED CONCRETE PAVEMENT, TYP. - REFER TO DETAILS AND COORDINATE WITH PLAYABLE FOUNTAIN CONTRACTOR
PORCELAIN PAVERS, TYP. - REFER TO ARCHITECTURAL AND STRUCTURAL PLANS FOR PAVERS ADJACENT TO BUILDINGS REFER TO SITE DETAILS AND SPECS FOR PAVERS UNDER CENTER CANOPY AND AT FIRE PIT AREA
EXISTING TREE TO REMAIN, TYP.
EXISTING LIGHTING, TYP. - REFER TO ELECTRICAL PLANS
VEHICULAR POLE LIGHTING, TYP. - REFER TO ELECTRICAL PLANS
PEDESTRIAN COLUMN / BOLLARD LIGHTING, TYP. - REFER TO ELECTRICAL PLANS
LEVEL LANDING, TYP. - REFER TO CIVIL PLANS
EXISTING STORM SEWER, TYP.
EXISTING SANITARY SEWER, TYP.
EXISTING WATER MAIN, TYP.
EXISTING ELECTRIC, TYP.
EXISTING GAS, TYP.
EXISTING WATER LINE, TYP.

Note Key:

- (1) BUILDING CANOPY AND SKYRING COLUMNS, TYP. - REFER TO ARCHITECTURAL PLANS
(2) EXISTING ROADWAY GUARDRAIL TO REMAIN
(3) EXISTING CONCRETE SIDEWALK TO REMAIN, TYP.
(4) EXISTING CONCRETE CURB AND GUTTER TO REMAIN, TYP.
(5) CONCRETE CURB AND GUTTER, TYP. - REFER TO CIVIL PLANS
(6) ASPHALT PARKING LOT PAVEMENT, TYP. - REFER TO CIVIL PLANS
(7) PARKING LOT STRIPING, TYP. - REFER TO CIVIL PLANS
(8) BARRIER-FREE PARKING SPACE SIGN, TYP. - REFER TO CIVIL PLANS
(9) CONCRETE TIERED SEATING AT LAKE HALL - REFER TO ARCHITECTURAL AND STRUCTURAL PLANS
(10) CONCRETE STEPS WITH HANDRAILS (HDRL-1) AND RETAINING WALLS, TYP. - REFER TO SITE DETAILS AND COORDINATE WITH CIVIL PLANS
(11) CONCRETE STEPS WITH HANDRAILS (HDRL-1) AND CHEEK WALLS, TYP. - REFER TO SITE DETAILS AND COORDINATE WITH CIVIL PLANS
(12) CONCRETE RAMP WITH HANDRAILS (HDRL-1) AND RETAINING WALLS - REFER TO SITE DETAILS AND COORDINATE WITH CIVIL PLANS
(13) CONCRETE RAMP WITH HANDRAILS ON BOTH SIDES (HDRL-1) - REFER TO SITE DETAILS AND COORDINATE WITH CIVIL PLANS
(14) CONCRETE RAMP WITH HANDRAIL ON WEST SIDE (HDRL-1) AND GUARDRAIL ON EAST SIDE (GDRL-2) PROVIDE SMOOTH TRANSITION BETWEEN RAMP GUARDRAIL AND DECKING HANDRAIL - REFER TO SITE DETAILS AND COORDINATE WITH CIVIL AND STRUCTURAL PLANS
(15) 3' HT. CONCRETE PLANTER CURB, TYP. - REFER TO SITE DETAILS
(16) RETAINING WALL WITH GUARDRAIL (GDRL-1) - REFER TO CIVIL PLANS
(17) CONCRETE RETAINING WALL - REFER TO CIVIL AND STRUCTURAL PLANS
(18) PLANTER WALL, TYP. - REFER TO ARCHITECTURAL AND STRUCTURAL PLANS
(19) PRECAST CONCRETE BLOCK RETAINING WALL, 30" HT. MAX, TYP. - REFER TO SITE DETAILS AND SPECS, AND COORDINATE WITH CIVIL PLANS
(20) PRECAST CONCRETE BLOCK RETAINING WALL WITH GUARDRAIL (GDRL-1) - REFER TO SITE DETAILS AND SPECS, AND COORDINATE WITH CIVIL PLANS
(21) BOLLARDS, TYP. - REFER TO CIVIL PLANS
(22) FIRE PIT - REFER TO ARCHITECTURAL PLANS
(23) CONCRETE SLAB FOR TABLES (QTY. 3) - REFER TO SITE FURNISHINGS PLAN
(24) SYNTHETIC WOOD BOARDWALK WITH HANDRAIL (HDRL-2) - REFER TO STRUCTURAL PLANS
(25) SYNTHETIC WOOD DECKING WITH HANDRAIL (HDRL-2) - REFER TO STRUCTURAL PLANS
(26) SYNTHETIC WOOD STEPS WITH HANDRAIL (HDRL-3) AT LAKE HOUSE - REFER TO STRUCTURAL PLANS
(27) SYNTHETIC WOOD TIERED SEATING AT LAKE HOUSE, TYP. - REFER TO STRUCTURAL PLANS
(28) SYNTHETIC WOOD FISHING PIER WITH HANDRAIL (HDRL-2) - REFER TO STRUCTURAL PLANS
(29) SYNTHETIC WOOD BOAT DOCK, TYP. - REFER TO STRUCTURAL PLANS
(30) DUMPSTER ENCLOSURE - REFER TO ARCHITECTURAL PLANS
(31) 4' HT. ORNAMENTAL FENCE AND GATES, TYP. - REFER TO SITE DETAILS AND SPECS
(32) PLAYGROUND WITH SYNTHETIC TURF SURFACING (PLAY FEATURES BY OTHERS) - REFER TO SITE DETAILS
(33) PLAYABLE FOUNTAIN (FOUNTAIN FEATURES BY OTHERS)
(34) MONUMENT SIGN - REFER TO ARCHITECTURAL AND CIVIL PLANS
(35) IDENTITY ELEMENT / SCULPTURE (BY OTHERS)
(36) LAKE HOUSE MECHANICAL UNIT WITH CONCRETE PAD - REFER TO ARCHITECTURAL AND MECHANICAL PLANS
(37) LAKE HALL TRANSFORMER WITH CONCRETE PAD - REFER TO ARCHITECTURAL AND ELECTRICAL PLANS
(38) LAKE HALL MECHANICAL UNIT WITH CONCRETE PAD - REFER TO ARCHITECTURAL AND MECHANICAL PLANS
(39) LAKE HALL GENERATOR WITH CONCRETE PAD - REFER TO ELECTRICAL PLANS
(40) SCREEN FENCE ENCLOSURE WITH ACCESS GATES AND INTERIOR STONE SURFACE - REFER TO ARCHITECTURAL AND CIVIL PLANS
(41) CONCRETE SLAB FOR BIKE RACKS (QTY. 2) - REFER TO SITE FURNISHINGS PLAN
(42) CONCRETE SLAB FOR DRINKING FOUNTAIN - REFER TO SITE FURNISHINGS PLAN

Supported Slab Note:

1. COORDINATE THE LOCATION OF SUPPORTED SLABS WITH ARCHITECTURAL PLANS AND DETAILS. ADJUST PROPOSED CONCRETE PAVEMENT SCORING PATTERN AS NECESSARY TO ACCOMMODATE.

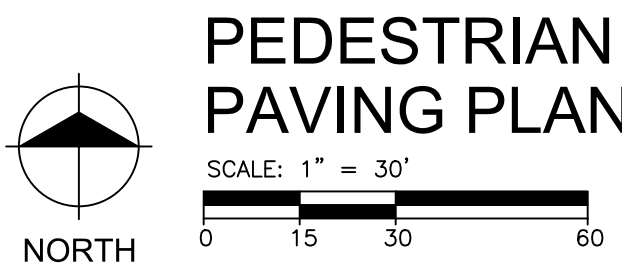

REVISIONS

10/27/2026	ADDENDUM NO. 2
10/12/2026	BIDS AND PERMITS
09/25/2026	SITE PLAN REVIEW
09/21/2026	CD PEER REVIEW
09/09/2026	CD TEAM REVIEW
08/10/2026	CD 50% PROGRESS
08/22/2026	DD OWNER REVIEW
08/15/2026	DD PEER REVIEW
06/08/2026	DD 90% PROGRESS
05/18/2026	DD 50% PROGRESS
02/23/2026	SD OWNER REVIEW
02/13/2026	SD PEER REVIEW
02/09/2026	SD PROGRESS REVIEW

Drawn By BBOUCHARD
Designer PANDRIESE
Reviewer PANDRIESE
Manager CKRETOVIC


Hard copy is intended to be 24"x36" when plotted. Scale(s) indicated and graphic quality may not be accurate for any other size.

PROJECT NO.
2500281

SHEET NO.


L101

© Copyright 2025
All Rights Reserved

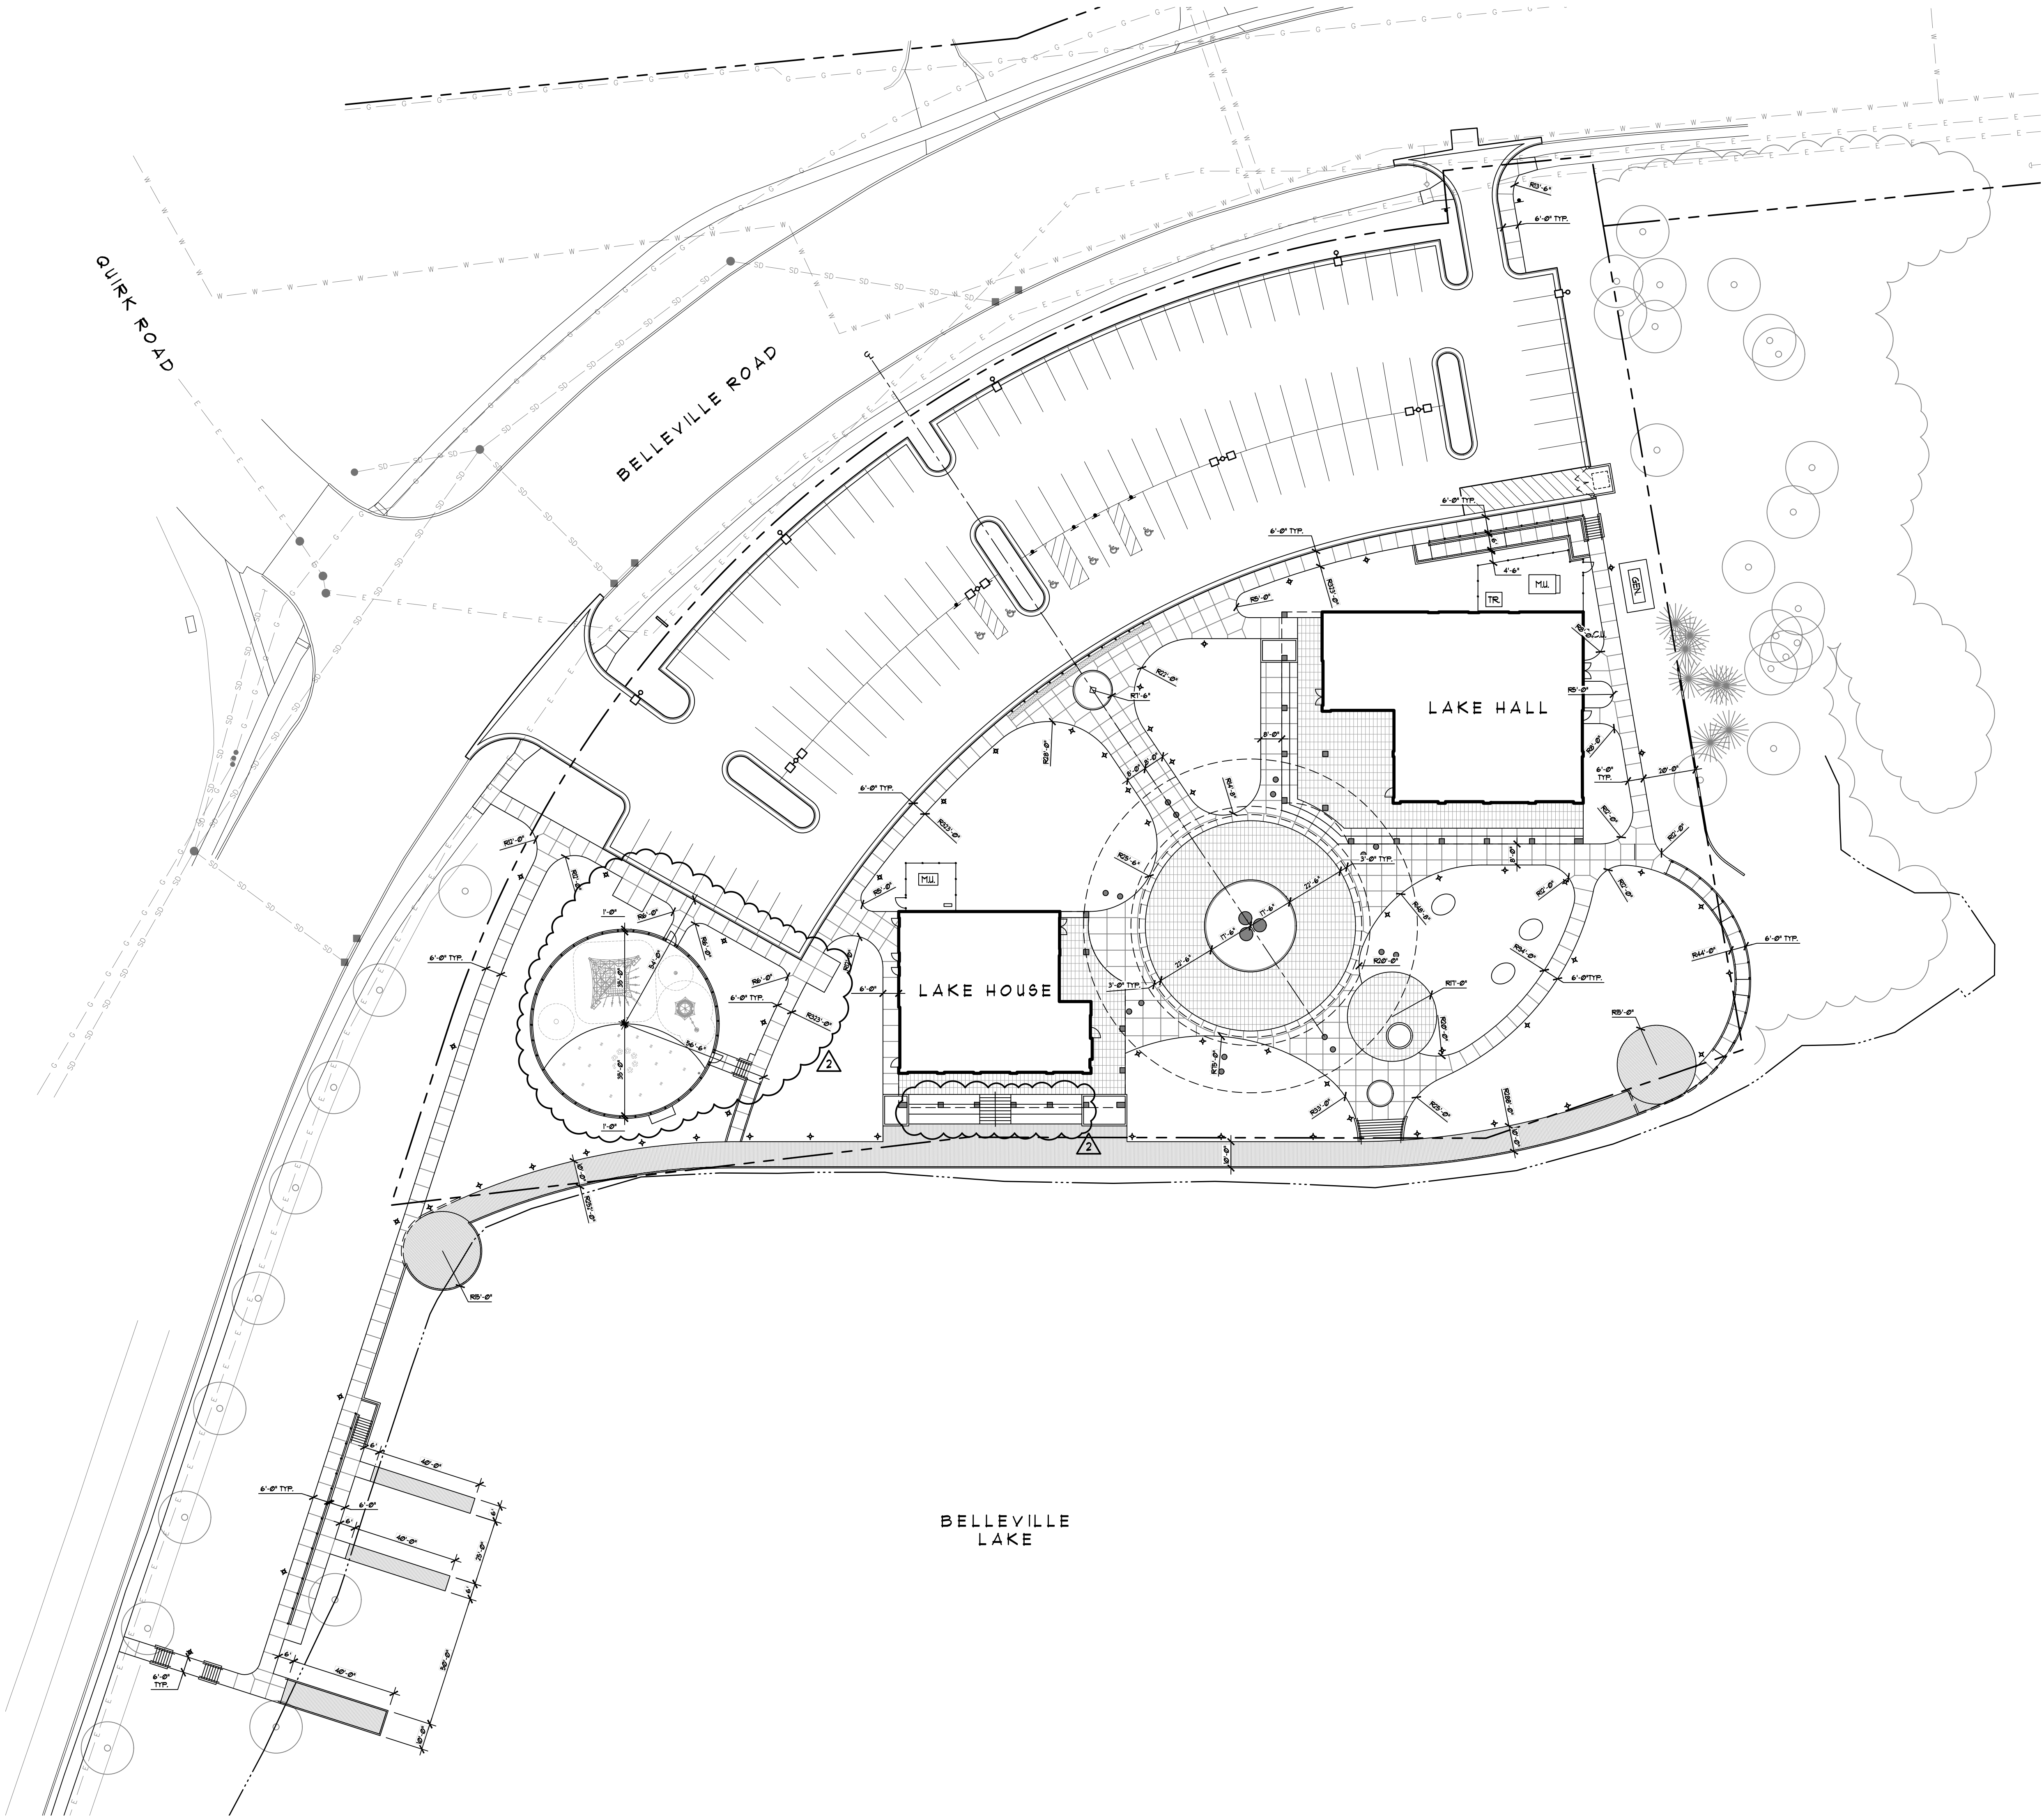

Layout Notes:

1. LAYOUT TO BE PROVIDED BY A REGISTERED SURVEYOR.
2. ALL DIMENSIONS ARE TO BACK OF CURB, AS APPLICABLE, UNLESS OTHERWISE NOTED.
3. ANY DISCREPANCIES IN SITE LAYOUT SHALL BE BROUGHT TO THE ATTENTION OF THE OWNER'S REPRESENTATIVE AND LANDSCAPE ARCHITECT PRIOR TO PROCEEDING.
4. MEET ALL EXISTING ROAD PAVEMENT, CURBS, GUTTERS AND SIDEWALKS FLUSH AT EXISTING WIDTHS AS SHOWN ON THE PLANS.
5. RADIAL FORMS THAT ARE CONTINUOUS WITH ABUTTING GEOMETRY ARE TO INTERSECT AT A POINT OF TANGENCY, TYPICAL.
6. ELECTRONIC FILES ARE AVAILABLE UPON REQUEST FOR LAYOUT PURPOSES.

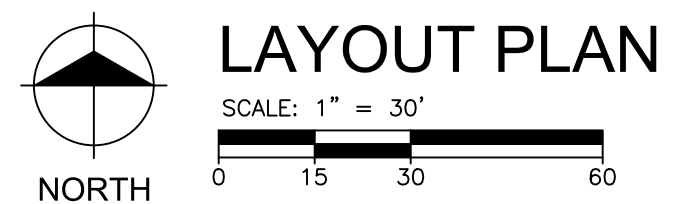

GRISSIM
METZ ASSOCIATES
ANDRIESE
Landscape Architecture

fishbeck
Engineers | Architects | Scientists | Constructors

Van Buren Charter Township

Van Buren Township, MI

The Lakeside Park

REVISIONS

10/27/2026	ADDENDUM NO. 2
10/12/2026	BIDS AND PERMITS
09/25/2026	SITE PLAN REVIEW
09/21/2026	CD PEER REVIEW
09/09/2026	CD TEAM REVIEW
08/10/2026	CD 50% PROGRESS
08/22/2026	DD OWNER REVIEW
08/15/2026	DD PEER REVIEW
06/08/2026	DD 90% PROGRESS
05/18/2026	DD 50% PROGRESS
02/23/2026	SD OWNER REVIEW
02/13/2026	SD PEER REVIEW
02/09/2026	SD PROGRESS REVIEW

Drawn By BBOUCHARD
Designer PANDRIESE
Reviewer PANDRIESE
Manager CKRETOVIC

Hard copy is intended to be 24"x36" when plotted. Scale(s) indicated and graphic quality may not be accurate for any other size.


PROJECT NO.

2500281

SHEET NO.


L201

© Copyright 2025
All Rights Reserved

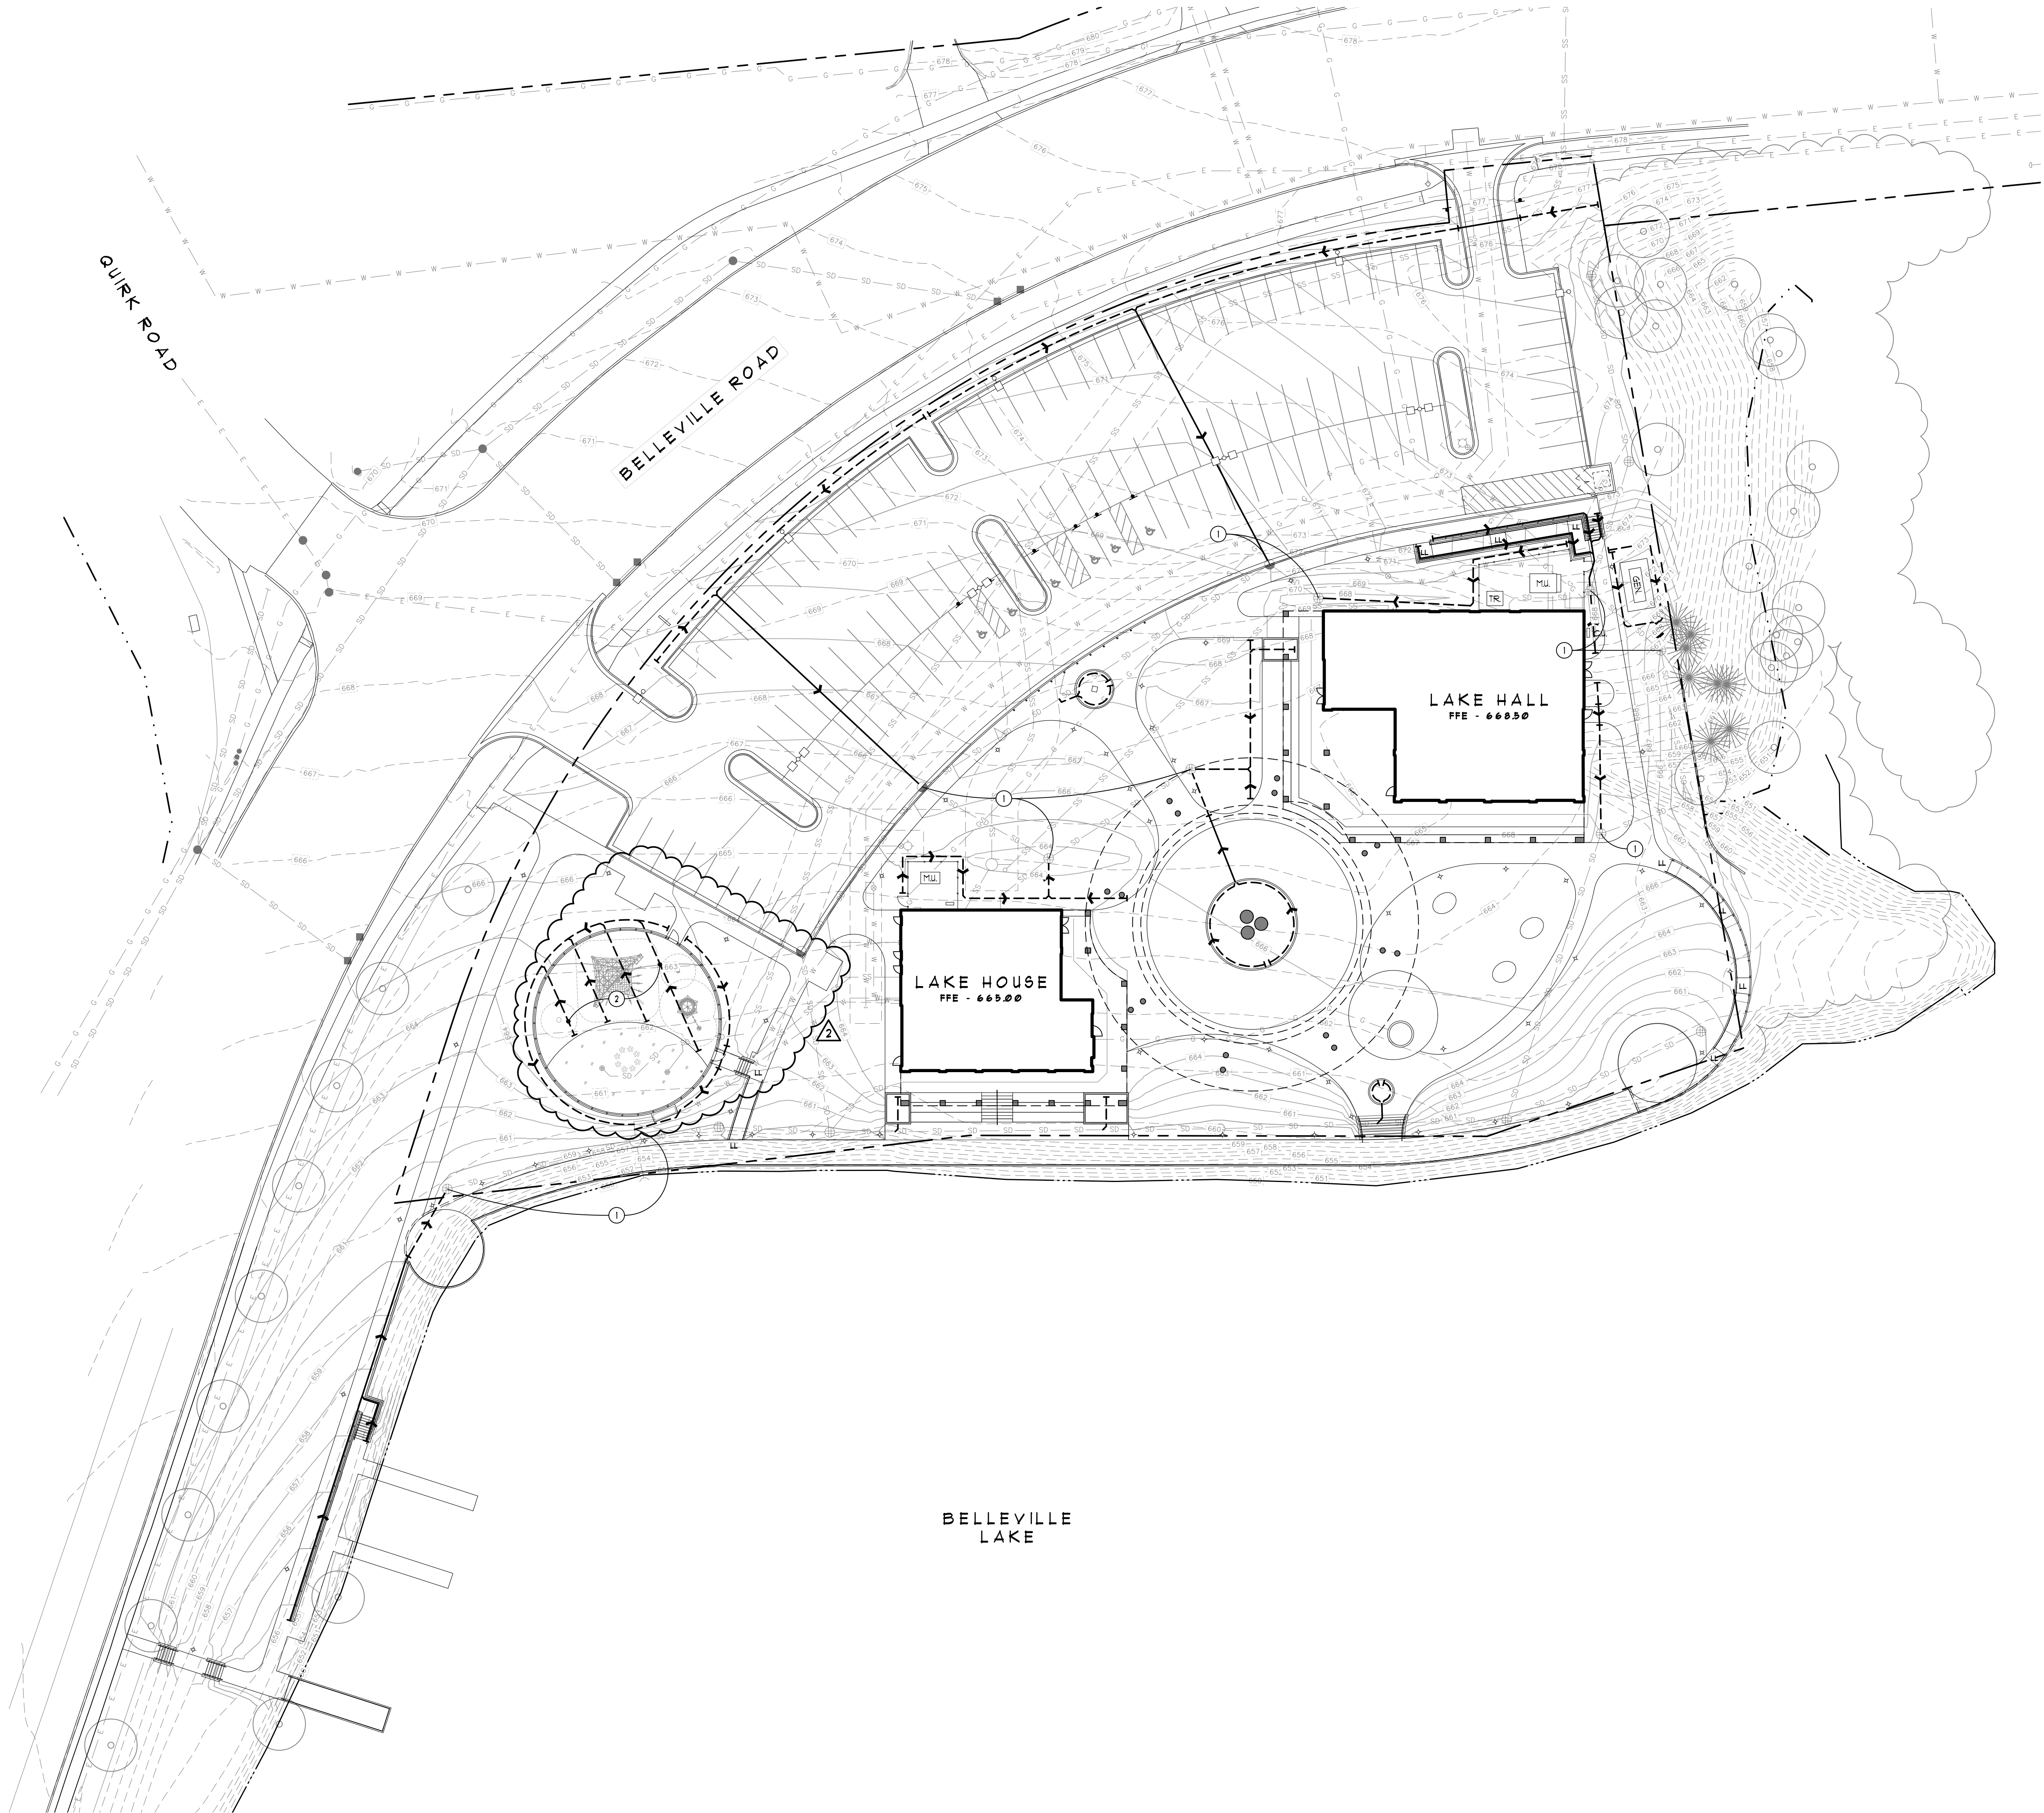

Landscape Underdrainage Legend:

LL	LEVEL LANDING, TYP. - REFER TO CIVIL PLANS
SD	EXISTING / PROPOSED STORM SEWER, TYP.
SS	EXISTING / PROPOSED SANITARY SEWER, TYP.
W	EXISTING / PROPOSED WATER MAIN, TYP.
E	EXISTING / PROPOSED ELECTRIC, TYP.
G	EXISTING / PROPOSED GAS, TYP.
670	EXISTING CONTOUR MAJOR LINE, TYP.
668	EXISTING CONTOUR MINOR LINE, TYP.
670	PROPOSED CONTOUR MAJOR LINE, TYP. - REFER TO CIVIL PLANS
668	PROPOSED CONTOUR MINOR LINE, TYP. - REFER TO CIVIL PLANS
668	EXISTING WATER LINE, TYP.

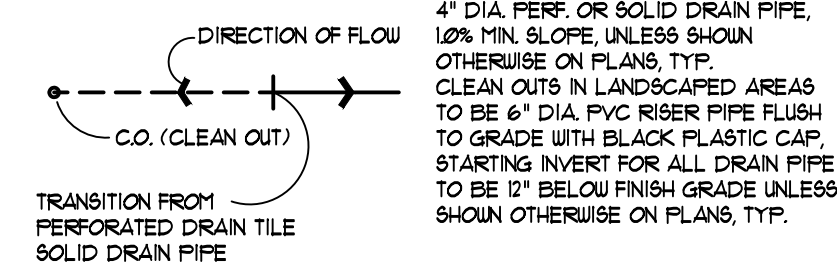

Note Key:

- LANDSCAPE UNDERDRAINAGE TIE-IN LOCATIONS TO STORM SYSTEM, TYP. - REFER TO CIVIL PLANS
- COORDINATE SYNTHETIC TURF UNDERDRAINAGE LAYOUT WITH PLAYGROUND INSTALLER TO AVOID CONFLICTS WITH PLAY STRUCTURE FOOTINGS, TYP.

Landscape Underdrainage Notes:

- PROTECT ALL NEW AND EXISTING UTILITIES, LIGHTS, PAVEMENT, POLES, ETC. DURING CONSTRUCTION.
- RESTORE ANY DAMAGED INFRASTRUCTURE TO PRE-CONSTRUCTION CONDITIONS PER SPECIFICATIONS.
- ALL DISTURBED LAWN AREAS SHALL BE RESTORED IN ACCORDANCE WITH THE LANDSCAPE PLANS.
- THE CONTRACTOR SHALL VERIFY ALL EXISTING CONDITION INFORMATION SHOWN PRIOR TO CONSTRUCTION. NOTIFY THE OWNER'S REPRESENTATIVE AND LANDSCAPE ARCHITECT OF ANY CONCERNS PRIOR TO PROCEEDING.
- LOCATE ALL EXISTING UNDERGROUND UTILITIES PRIOR TO BEGINNING ANY EXCAVATION WORK.
- THE CONTRACTOR SHALL NOTE EXISTING UNDERGROUND UTILITIES WITHIN AND ADJACENT TO THE SITE. BACKFILL FOR EXISTING UTILITY TRENCHES SHALL BE EXAMINED CRITICALLY. ANY TRENCHES FOUND TO HAVE SOFT, UNSTABLE OR UNSUITABLE BACKFILL MATERIAL, THAT ARE TO BE WITHIN THE ZONE OF INFLUENCE OF PROPOSED PAVEMENT SHALL BE COMPLETELY EXCAVATED AND BACKFILLED WITH SUITABLE MATERIAL.
- MATCH PROPOSED GRADES TO EXISTING GRADES AT THE LIMIT OF WORK, AS INDICATED AT EACH PROPOSED CONTOUR, AND AS INDICATED SPECIFICALLY ON THE PLANS.
- THE STAGING OF CONSTRUCTION ACTIVITIES SHALL OCCUR ONLY WITHIN THE SITE BOUNDARIES. ANY CONSTRUCTION ACTIVITIES OUTSIDE OF THE SITE BOUNDARIES SHALL BE AT THE SOLE RESPONSIBILITY AND RISK OF THE CONTRACTOR.
- ALL WALK RAMP ARE TO BE IN COMPLIANCE WITH MOOT R-38 SERIES STANDARD PLANS FOR SIDEWALK RAMPS AND IN COMPLIANCE WITH ADA STANDARDS.
- REFER TO CIVIL PLANS FOR ALL SOIL EROSION AND SEDIMENTATION CONTROL (SESC) MEASURES AND NOTES.
- REFER TO CIVIL PLANS FOR ALL GRADING, DRAINAGE, AND UTILITY WORK.

REVISIONS

10/27/2026	ADDENDUM NO. 2
10/12/2026	BIDS AND PERMITS
09/25/2026	SITE PLAN REVIEW
09/21/2026	CD PEER REVIEW
09/09/2026	CD TEAM REVIEW
08/10/2026	CD 50% PROGRESS
08/22/2026	DD OWNER REVIEW
08/15/2026	DD PEER REVIEW
06/08/2026	DD 90 % PROGRESS
05/18/2026	DD 50 % PROGRESS
02/23/2026	SD OWNER REVIEW
02/13/2026	SD PEER REVIEW
02/09/2026	SD PROGRESS REVIEW

Drawn By	BBOUCHARD
Designer	PANDRIESE
Reviewer	PANDRIESE
Manager	CKRETOVIC


Hard copy is intended to be 24"x36" when plotted. Scale(s) indicated and graphic quality may not be accurate for any other size.

PROJECT NO.
2500281

SHEET NO.

L301

© Copyright 2025
All Rights Reserved

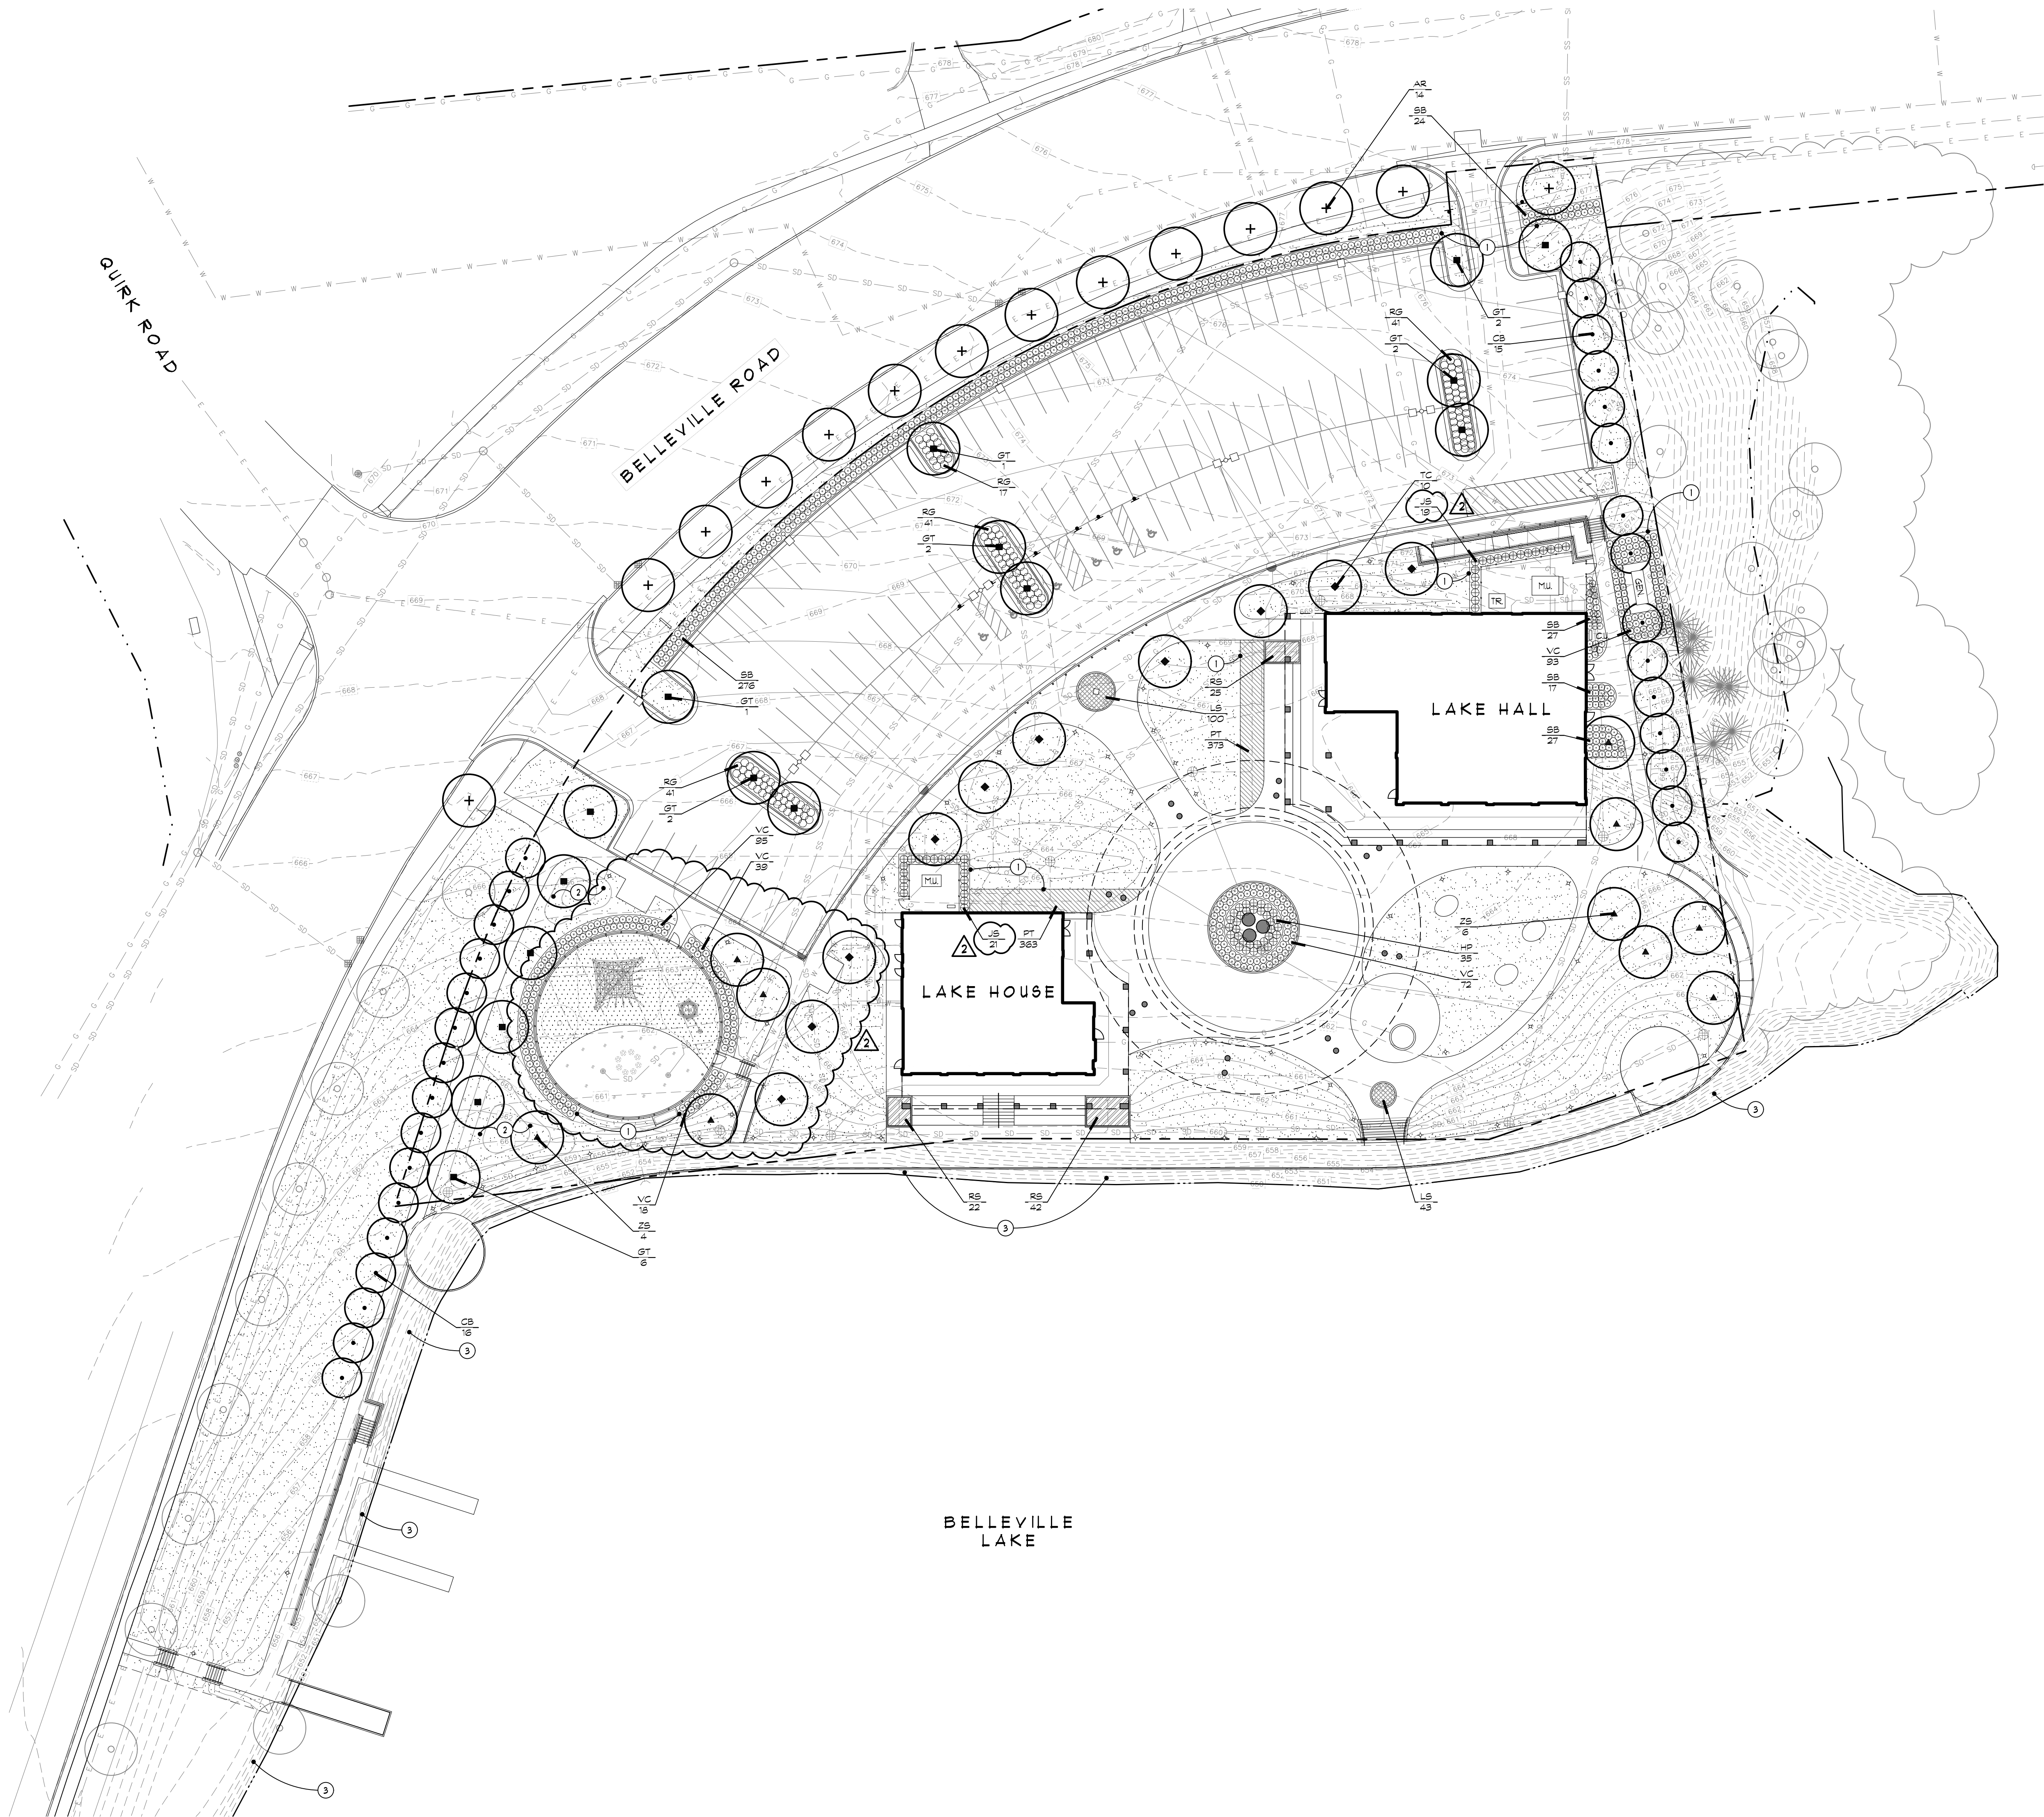

Landscape Legend:

- PLANT CODE
CALIPER SIZE, IF APPLICABLE
QUANTITY
- SODDED AND IRRIGATED LAWN ON 3" DEPTH TOPSOIL, TYP.
- PLAYGROUND SYNTHETIC TURF SURFACING - REFER TO SITE DETAILS
- LIMIT OF SODDED LAWN, TYP.
- EXISTING TREE TO REMAIN, TYP.
- EXISTING / PROPOSED STORM SEWER, TYP.
EXISTING / PROPOSED SANITARY SEWER, TYP.
EXISTING / PROPOSED WATER MAIN, TYP.
EXISTING / PROPOSED ELECTRIC, TYP.
EXISTING / PROPOSED GAS, TYP.
EXISTING CONTOUR LINE, TYP.
PROPOSED CONTOUR MAJOR, TYP.
PROPOSED CONTOUR MINOR, TYP.
EXISTING WATER LINE, TYP.

Note Key:

- 1 ALUMINUM EDGING BETWEEN ALL PLANT BEDS AND LAWN, TYP. - REFER TO SPECs
2 LOW SCULPTED BERRIES, TYP. - COORDINATE WITH CIVIL GRADING PLANS
3 PROTECTED WATER-WILLOW PLANT SPECIES ALONG SHORELINE TO REMAIN UNDISTURBED THROUGHOUT CONSTRUCTION, TYP.

Landscape Notes:

1. ALL DISTURBED AREAS DUE TO CONSTRUCTION OPERATIONS SHALL BE RESTORED WITH NEW SODDED LAWN ON 3" OF TOPSOIL. REFER TO TOPSOIL SPECIFICATIONS.
2. ALL BED LINES AND MOW EDGES SHALL BE PAINTED OUT BY THE CONTRACTOR FOR APPROVAL BY THE OWNER'S REPRESENTATIVE AND LANDSCAPE ARCHITECT PRIOR TO CONSTRUCTION.
3. PROVIDE DOUBLE-PROCESSED SHREDDED BARK MULCH IN ALL SHRUB AND PERENNIAL, AND ORNAMENTAL GRASS BEDS, TYP. REFER TO LANDSCAPE PLANTING DETAILS FOR MULCH DEPTH.
4. PROTECT ALL NEW AND EXISTING UTILITIES, LIGHTS, PAVEMENT, POLES, ETC. DURING CONSTRUCTION AS INDICATED ON THE PLANS.
5. RESTORE ANY DAMAGED LANDSCAPE OR INFRASTRUCTURE TO PRE-CONSTRUCTION STATE PER SPECIFICATIONS.
6. THE CONTRACTOR SHALL VERIFY ALL EXISTING CONDITION INFORMATION PRIOR TO CONSTRUCTION. NOTIFY THE OWNER'S REPRESENTATIVE AND LANDSCAPE ARCHITECT OF ANY CONCERNS PRIOR TO PROCEEDING.
7. LOCATE ALL EXISTING UNDERGROUND UTILITIES PRIOR TO BEGINNING ANY EXCAVATION WORK.
8. PROPOSED UTILITIES SHOWN FOR REFERENCE ONLY. THE CONTRACTOR IS RESPONSIBLE FOR LOCATING ALL UTILITIES PRIOR TO CONSTRUCTION AND NOTIFYING THE OWNER'S REPRESENTATIVE AND LANDSCAPE ARCHITECT OF ANY CONCERNS PRIOR TO PROCEEDING.
9. REFER TO CIVIL PLANS FOR ALL SOIL EROSION AND SEDIMENTATION CONTROL. (SESC) MEASURES AND NOTES.

Plant List:

CODE	QTY	BOTANICAL / COMMON NAME	SIZE	REMARKS
TREES				
AR	14	Acer rubrum 'Red Sunset' Red Sunset Maple	3" cal.	B&B
CB	31	Carpinus betulus 'Frans Fontaine' Frans Fontaine Hornbeam	2.5" cal.	B&B
GT	16	Gleditsia triacanthos inermis 'Skyline' Skyline Honey Locust	3" cal.	B&B
TC	10	Tilia cordata 'Greenspire' Greenspire Littleleaf Linden	3" cal.	B&B
ZS	10	Zelkova serrata Japanese Zelkova	3" cal.	B&B
SHRUBS				
HP	35	Hydrangea paniculata 'Ivobob' Bobo Panicle Hydrangea	3 gal.	Plant 36" o.c.
JS	40	Juniperus sabina 'Broadmoor' Broadmoor Juniper	3 gal.	Plant 36" o.c.
RG	140	Rhus aromatica 'Gro-Low' Gro-Low Fragrant Sumac	3 gal.	Plant 36" o.c.
SB	371	Spiraea x humalda 'Anthony Waterer' Anthony Waterer Spirea	3 gal.	Plant 30" o.c.
VC	317	Viburnum cerasiifolium 'Koreanspice' Koreanspice Viburnum	3 gal.	Plant 36" o.c.
GROUND COVERS				
LS	143	Liriope spicata Creeping Lilyturf	1 gal.	Plant 15" o.c.
PT	736	Pachysandra terminalis Japanese Pachysandra	1 gal.	Plant 15" o.c.
RS	89	Rosa x 'Meisland' White Drift Groundcover Rose	3 gal.	Plant 24" o.c.

REVISIONS

10/27/2026	ADDENDUM NO. 2
10/12/2026	BIDS AND PERMITS
09/25/2026	SITE PLAN REVIEW
09/21/2026	CD PEER REVIEW
09/09/2026	CD TEAM REVIEW
08/10/2026	CD 50% PROGRESS
08/22/2026	DD OWNER REVIEW
08/15/2026	DD PEER REVIEW
08/08/2026	DD 90% PROGRESS
08/18/2026	DD 50% PROGRESS
02/23/2026	SD OWNER REVIEW
02/13/2026	SD PEER REVIEW
02/09/2026	SD PROGRESS REVIEW


Drawn By BBOUCHARD
Designer PANDRIESE
Reviewer PANDRIESE
Manager CKRETOVIC

Hard copy is intended to be 24"x36" when plotted. Scale(s) indicated and graphic quality may not be accurate for any other size.

PROJECT NO.
2500281

SHEET NO.

L501

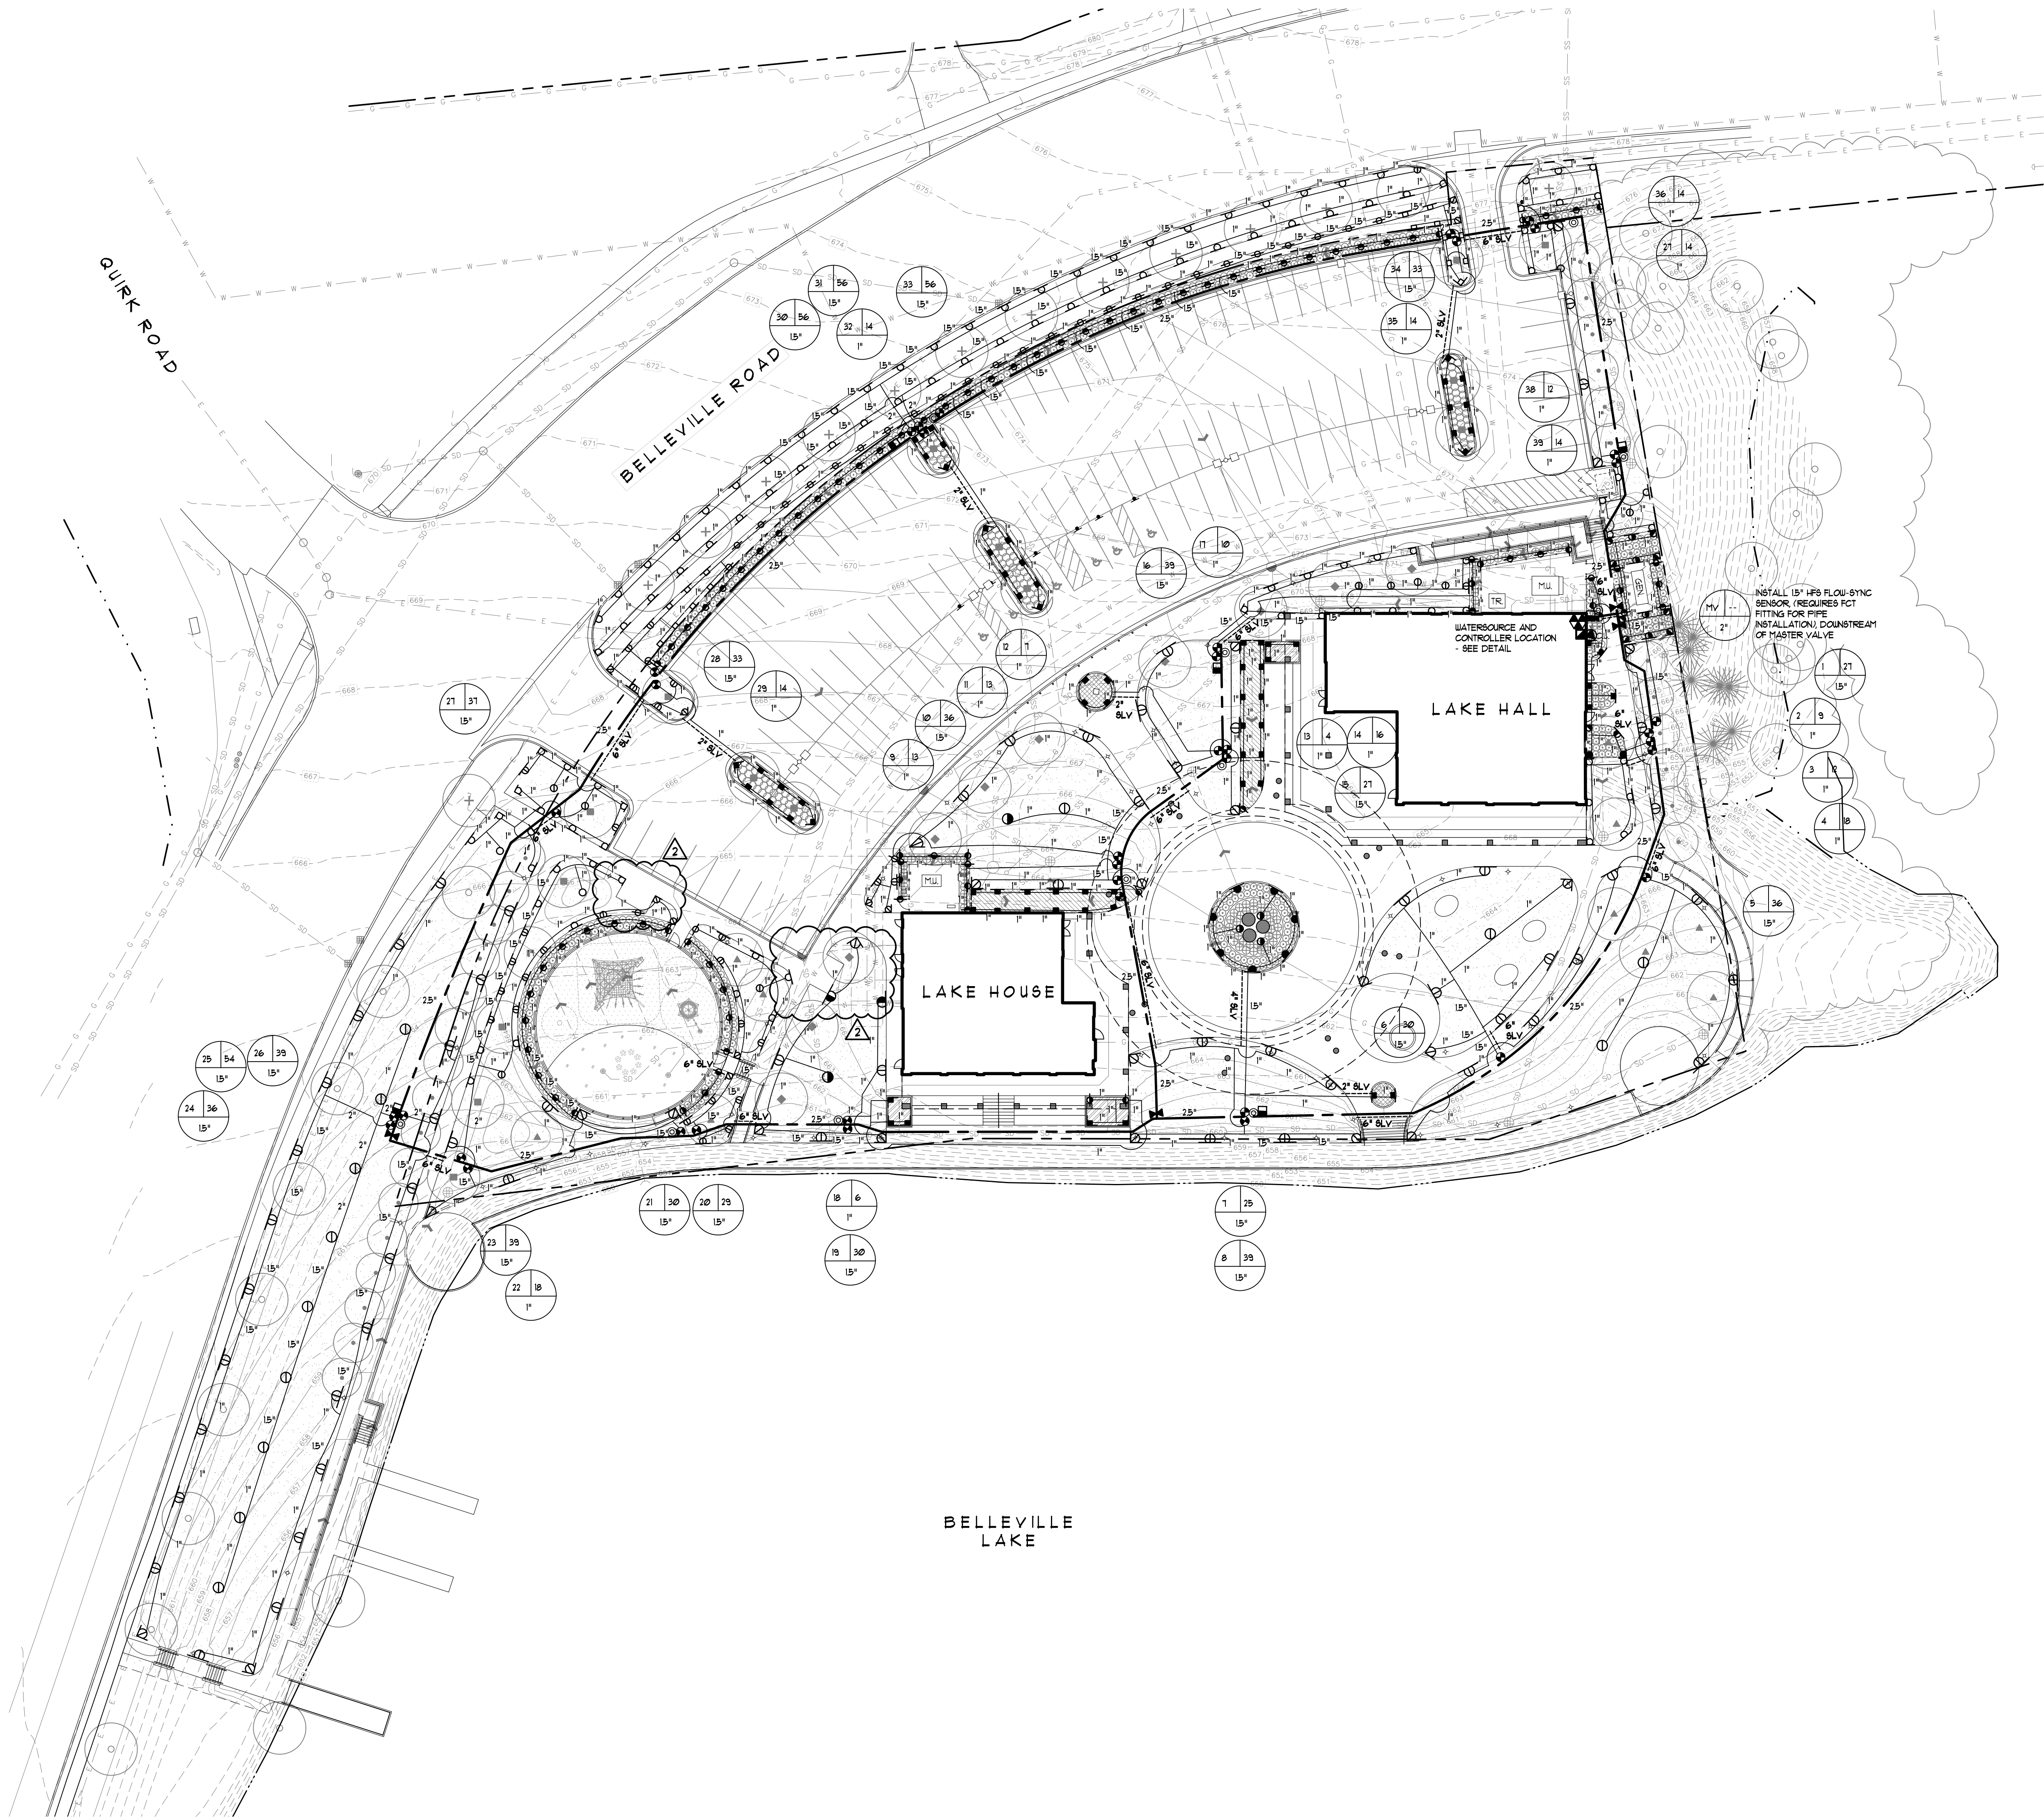

Irrigation Legend:

KEY	EQUIPMENT	HUNTER
4" Pop Up Spray w/	FR06-04-PR830-CV w/	Pro-Spray Fixed Nozzles
15' Radius Nozzle	15 Series Nozzle	15 Series Nozzle
12' Radius Nozzle	12 Series Nozzle	12 Series Nozzle
10' Radius Nozzle	10 Series Nozzle	10 Series Nozzle
Strip Spray Nozzle	66-530 Side, ES-515 End	
12" Pop Up Spray w/	FR06-12-PR830-CV w/	Pro-Spray Fixed Nozzles
15' Radius Nozzle	15 Series Nozzle	15 Series Nozzle
12' Radius Nozzle	12 Series Nozzle	12 Series Nozzle
10' Radius Nozzle	10 Series Nozzle	10 Series Nozzle
Strip Spray Nozzle	66-530 Side, ES-515 End	
Medium Rotary Sprinkler	1-20-04	
35' Radius, 3.0 GPM	3.0 Nozzle	
35' Radius, 6.0 GPM	6.0 Nozzle	
Medium Rotary Sprinkler	1-20-04	
25' Radius, 3.0 GPM	3.0 LA Nozzle	
25' Radius, 4.5 GPM	4.5 LA Nozzle	
Automatic Control Valve	ICV	
Quick Coupling Valve	QVC-100	
2" Watercourse	See Notes on Plans	
Wall mount two-wire controller with cellular module, subscription to Centra software, and hand held remote	A2C-TSD-6S A2C-LTE1 Cellular Module 15" HFS Flow-Sync sensor ROADM XL KIT	
Rain Sensor	Solar Sync	
Surge Arrestor	Hunter	
Isolation Valve - 2.5"	Nibco T113	

- Zone Number
- GPM for new zones
- Valve Size
- MAINLINE PIPE, CLASS 200 PVC, REFER TO SPECIFICATIONS
- LATERAL PIPE, PE 3408, 100 PSI, REFER TO SPECIFICATIONS
- 2" SLV SLEEVE TO BE INSTALLED BENEATH NEW PAVING, 24" BURY - SIZE AS SHOWN, INSTALLATION SHALL BE PART OF IRRIGATION SCOPE OF WORK

IRRIGATION PLAN

SCALE: 1" = 30'

Engineers | Architects | Scientists | Constructors

Van Buren Charter Township

Van Buren Township, MI

The Lakeside Park

REVIEWS

10/27/2026 ADDENDUM NO. 2

10/12/2026 BIDS AND PERMITS

09/25/2026 SITE PLAN REVIEW

09/21/2026 CD PEER REVIEW

09/09/2026 CD TEAM REVIEW

Drawn By BBOUCHARD

Designer PANDRIESE

Reviewer PANDRIESE

Manager CKRETOVIC

Hard copy is intended to be 24"x36" when plotted. Scale(s) indicated and graphic quality may not be accurate for any other size.

PROJECT NO.


2500281

SHEET NO.


L601

© Copyright 2025


All Rights Reserved

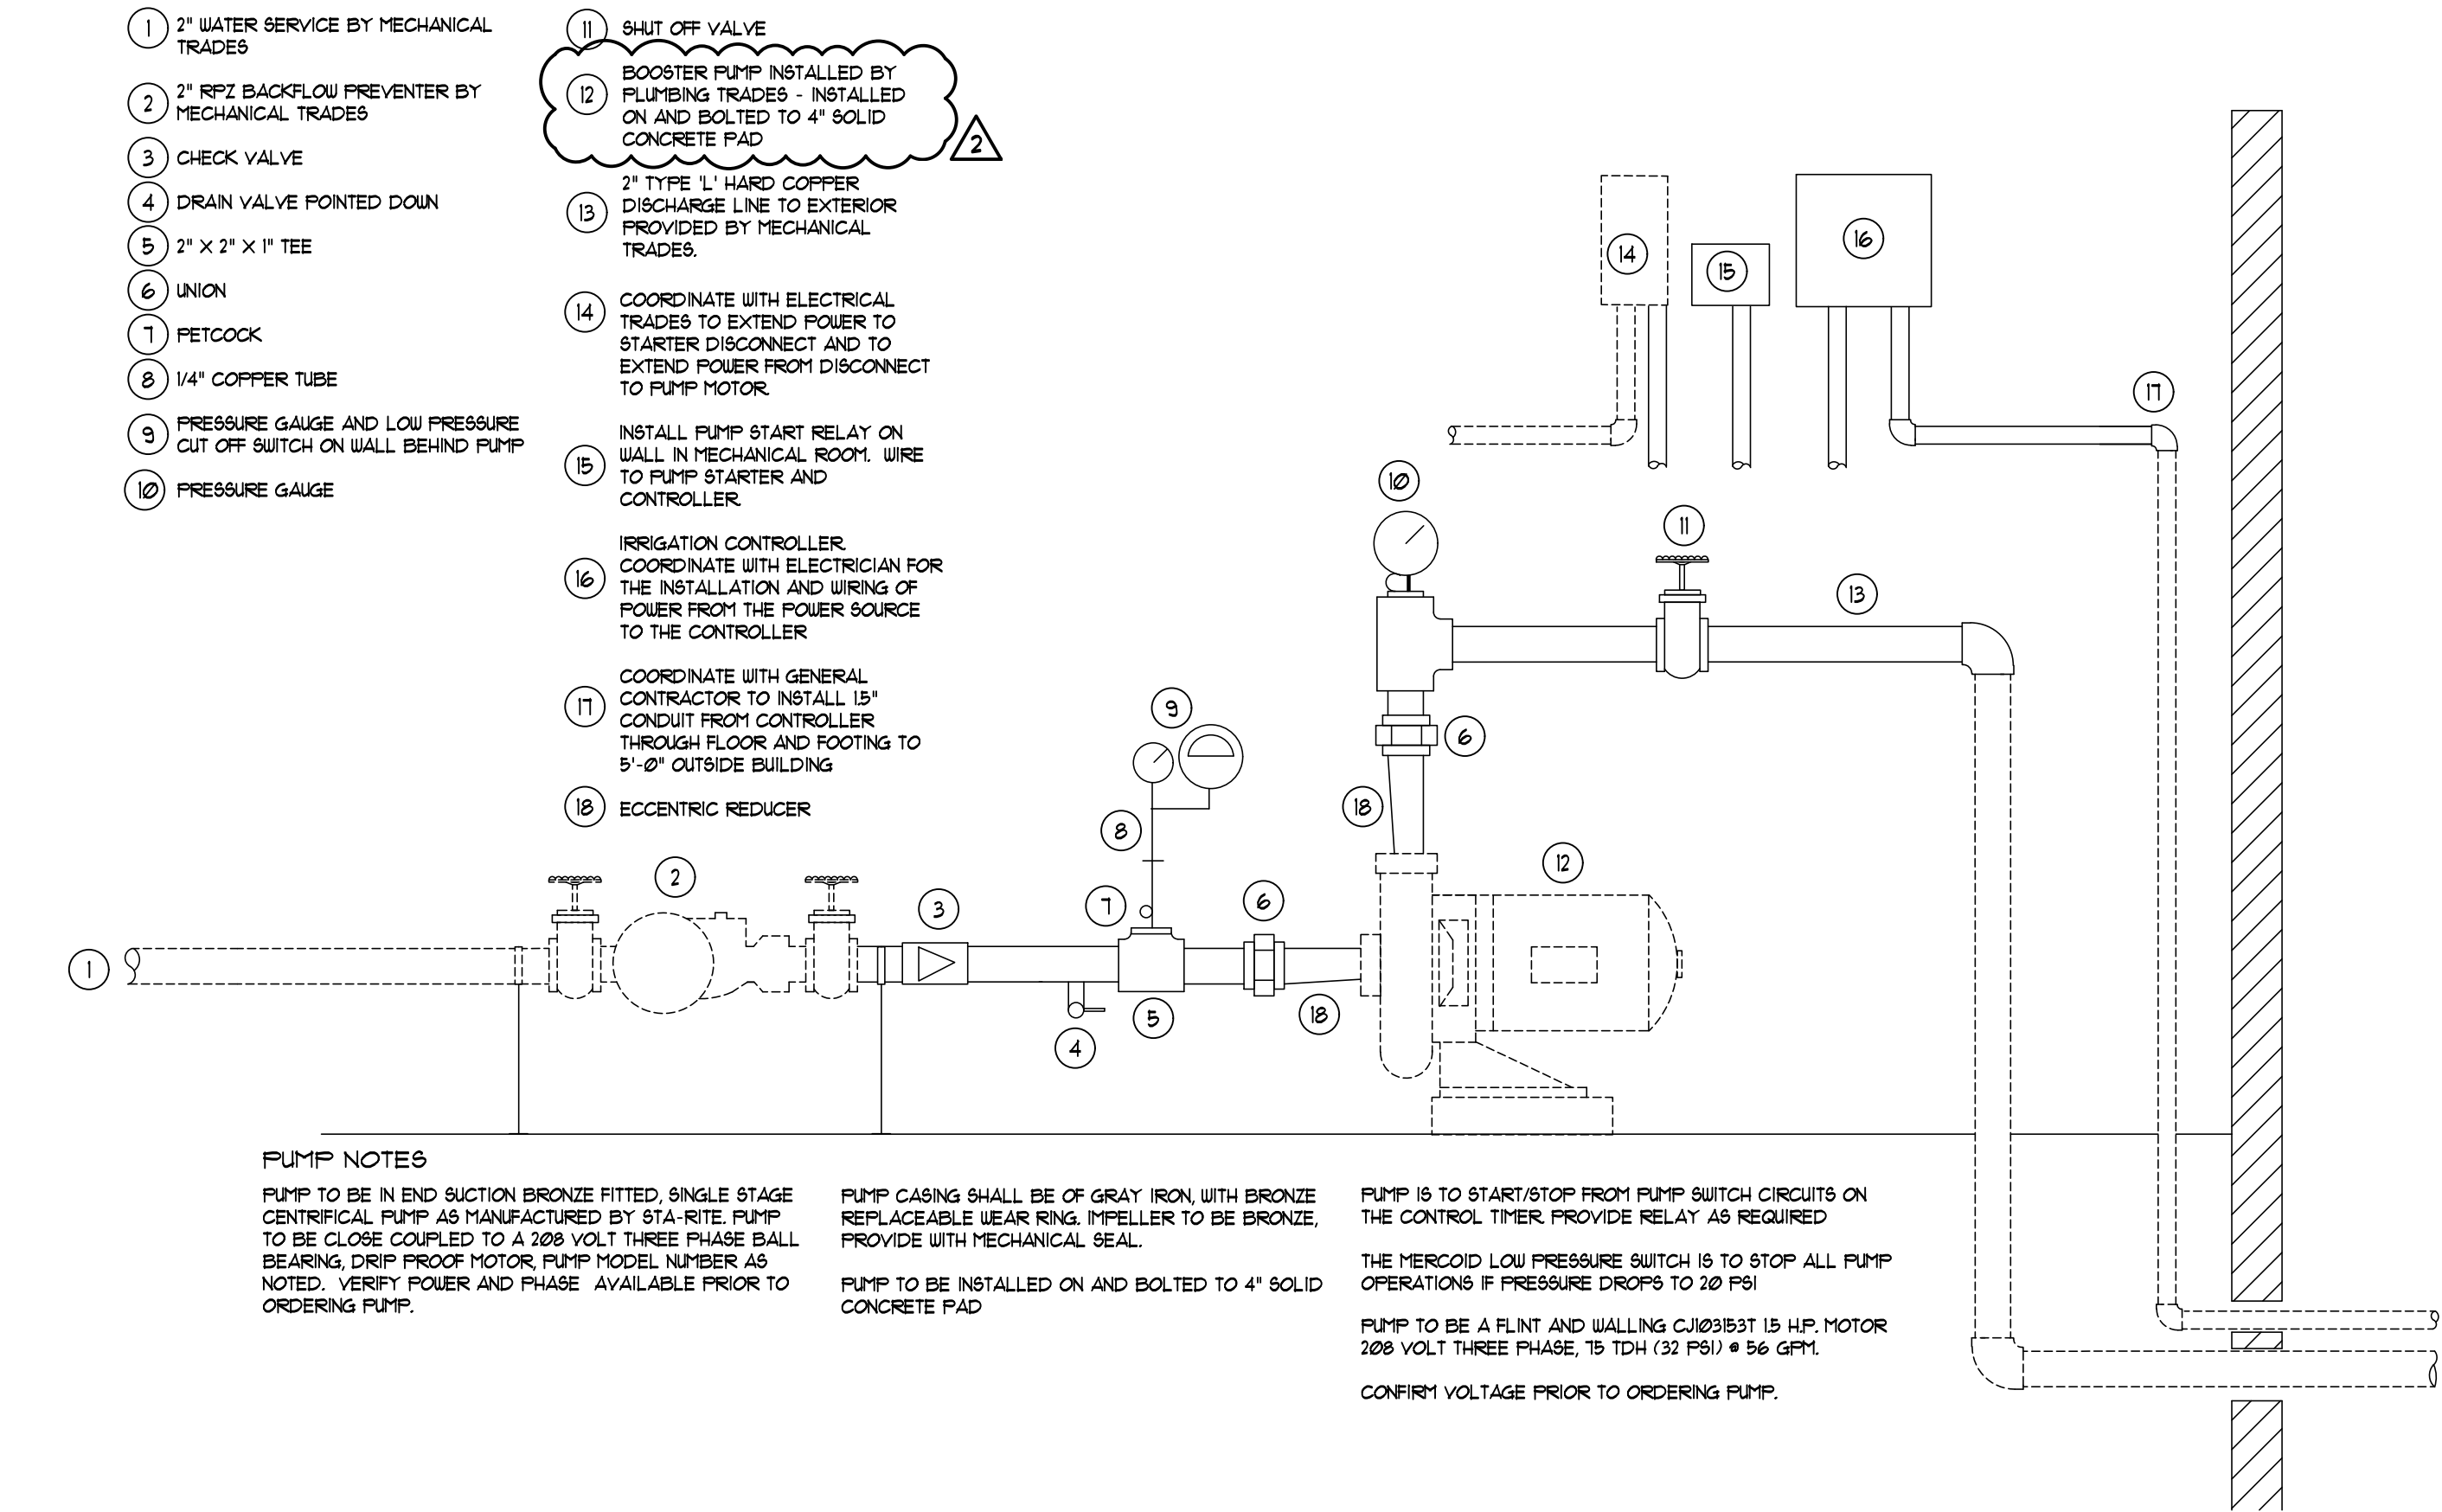


1 Schematic Watsource Detail
- NOT TO SCALE

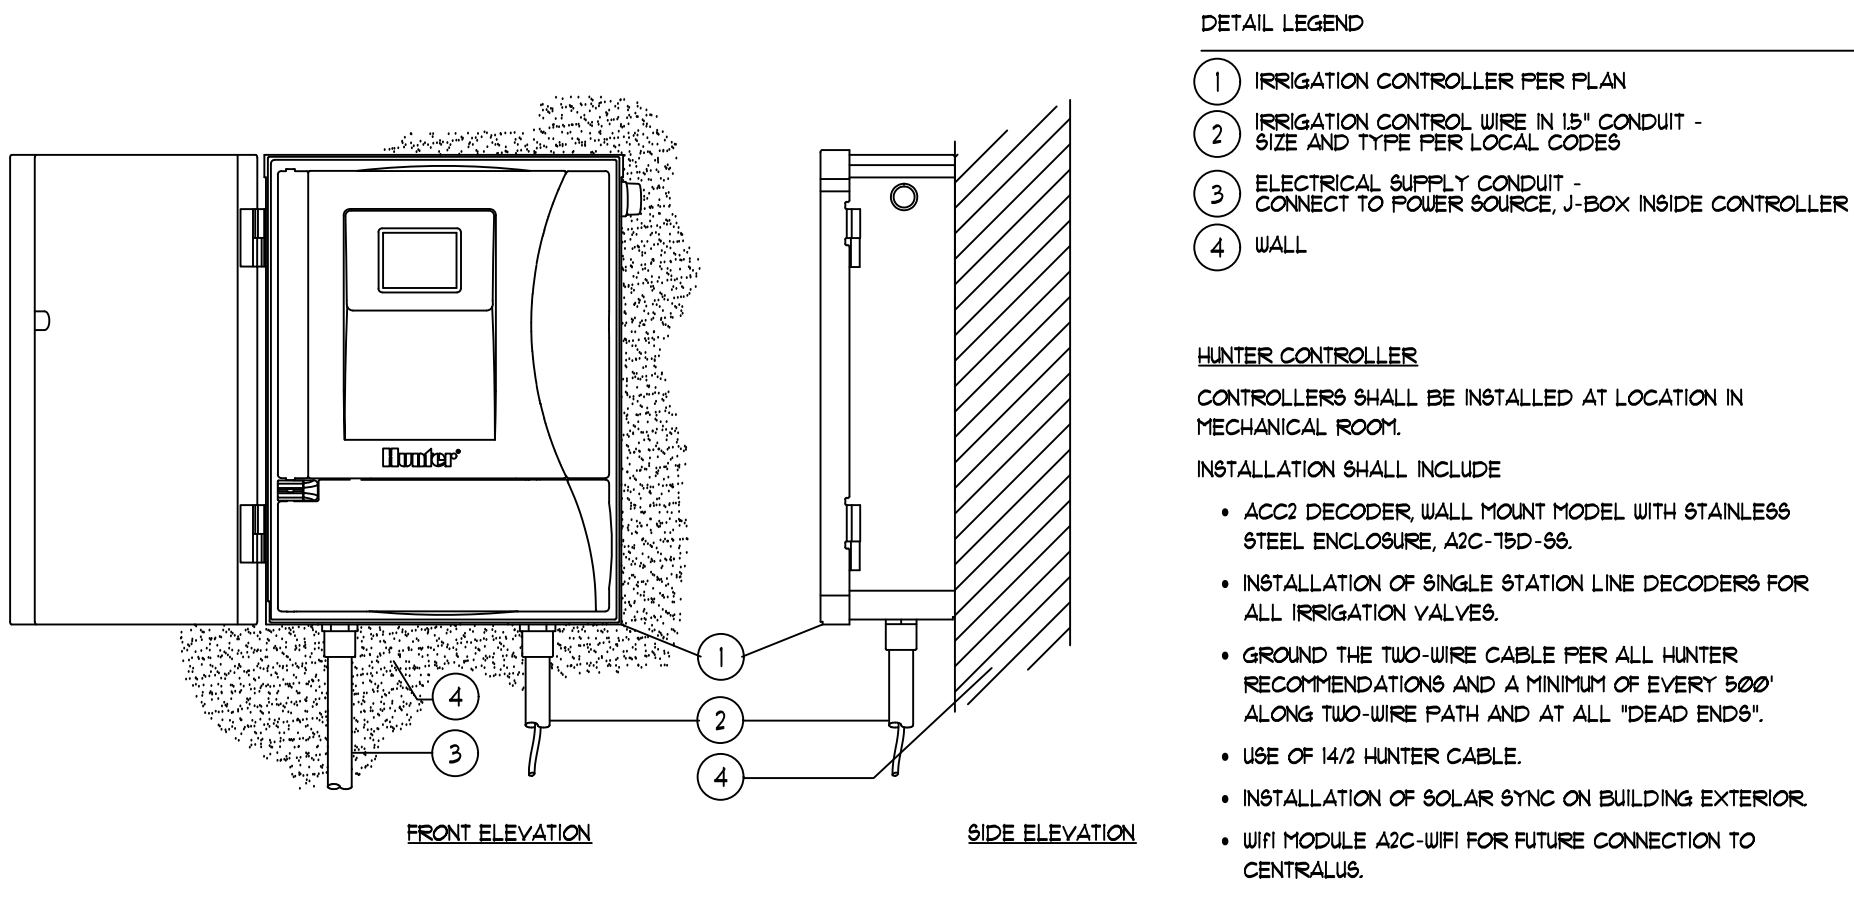


2 Controller Detail
- NOT TO SCALE

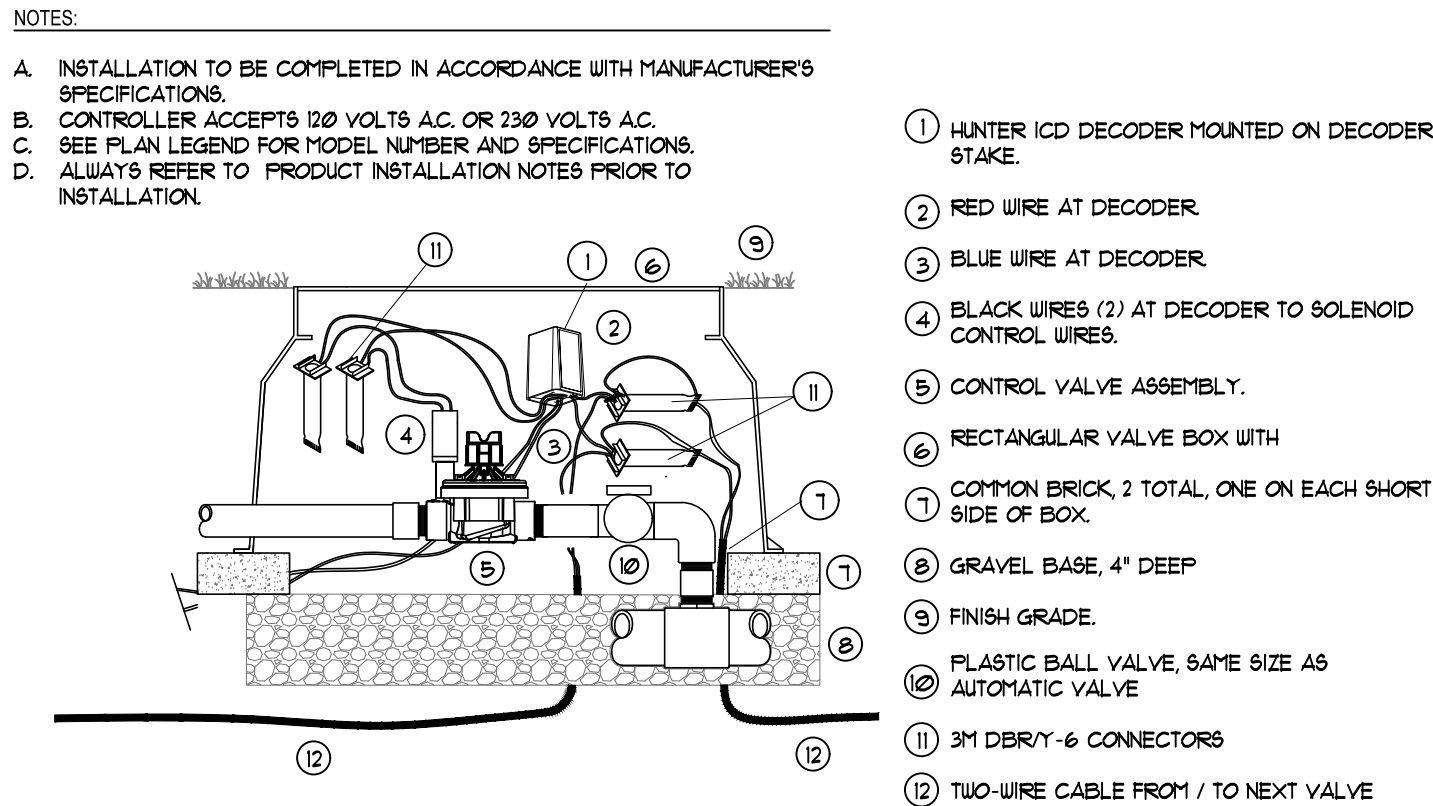


3 Automatic Valve Detail
- NOT TO SCALE

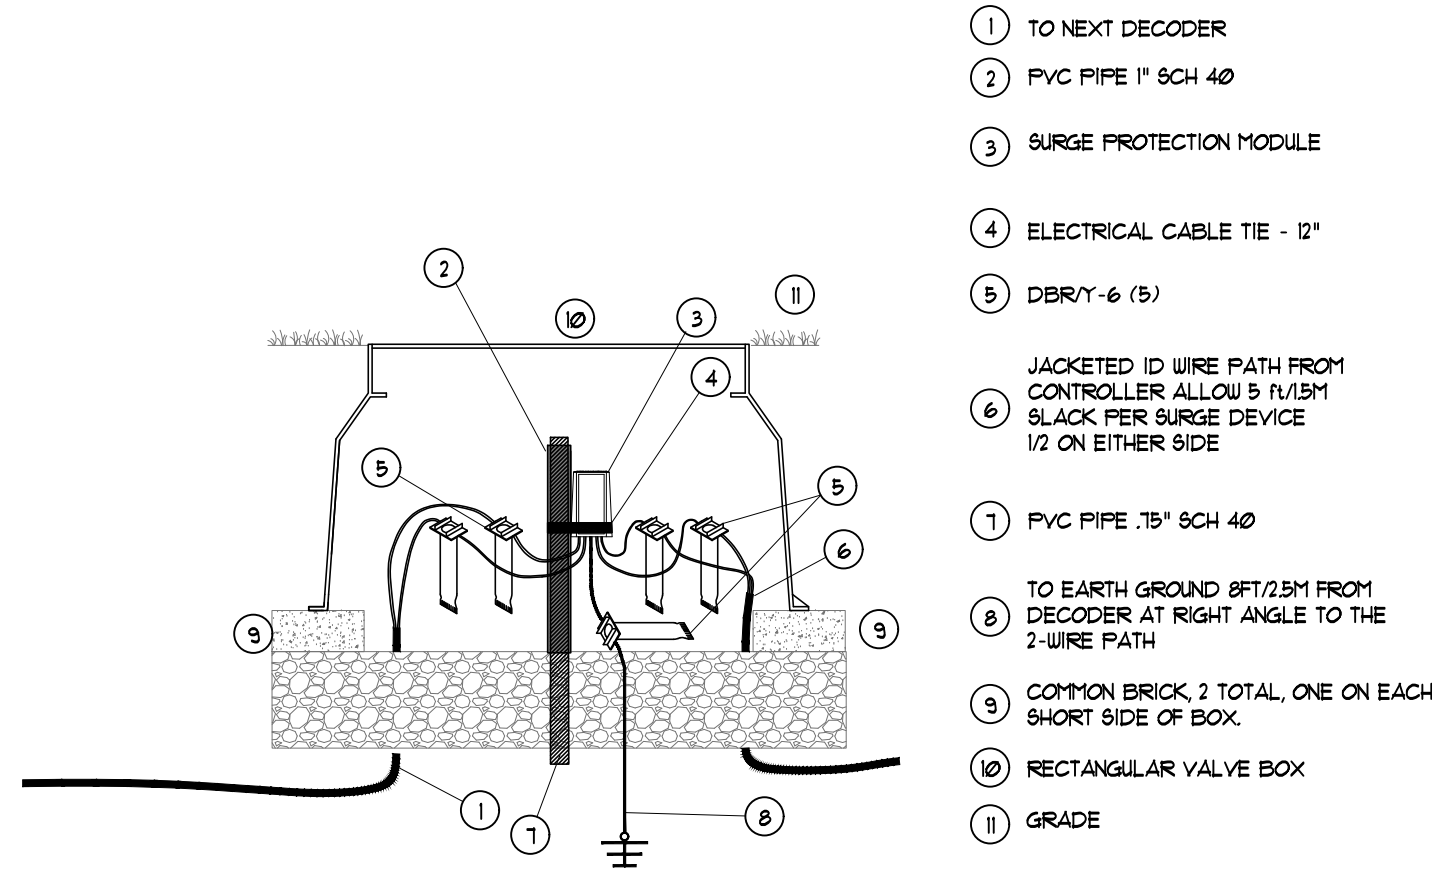


4 Grounding/Surge Arrestor Detail
- NOT TO SCALE

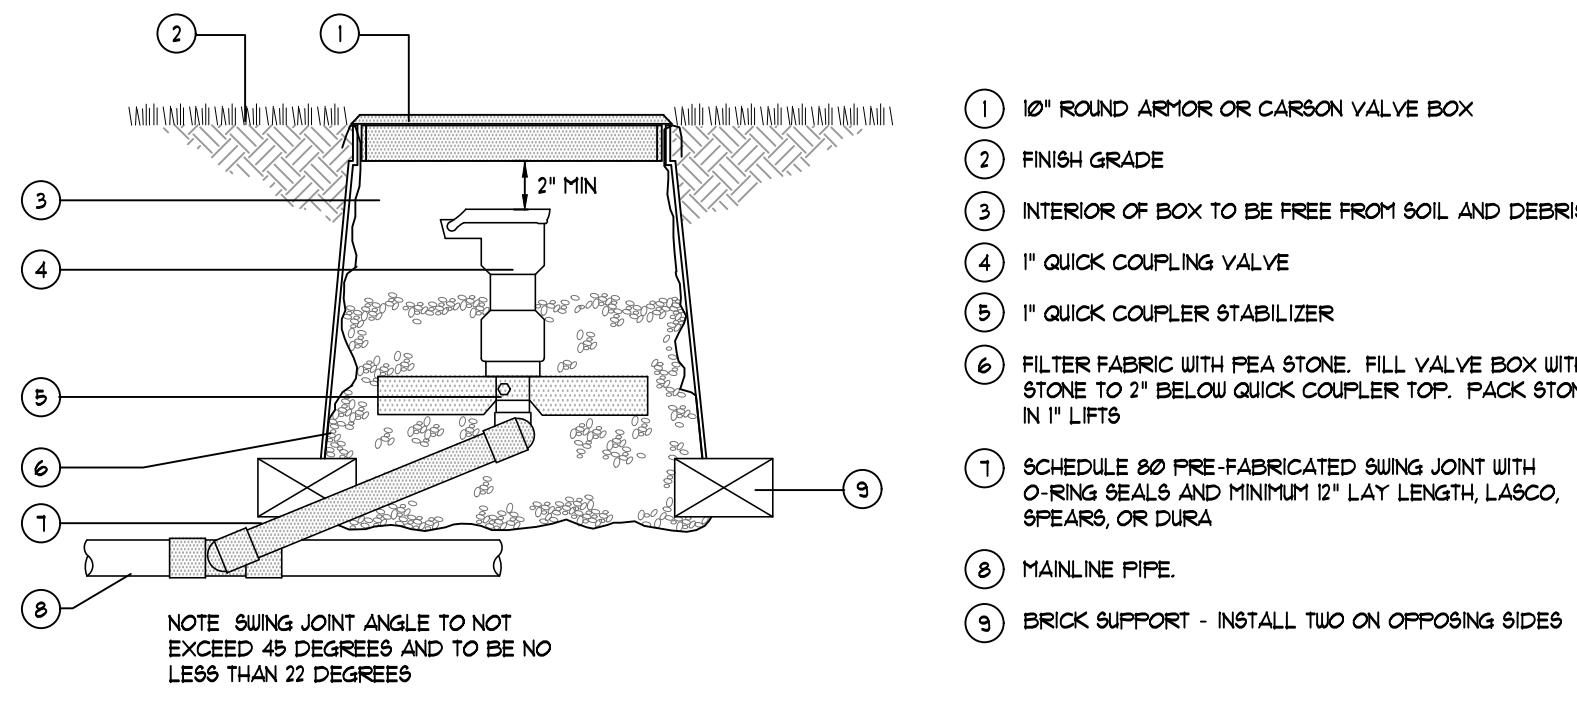

5 Quick Coupling Valve Detail
- NOT TO SCALE

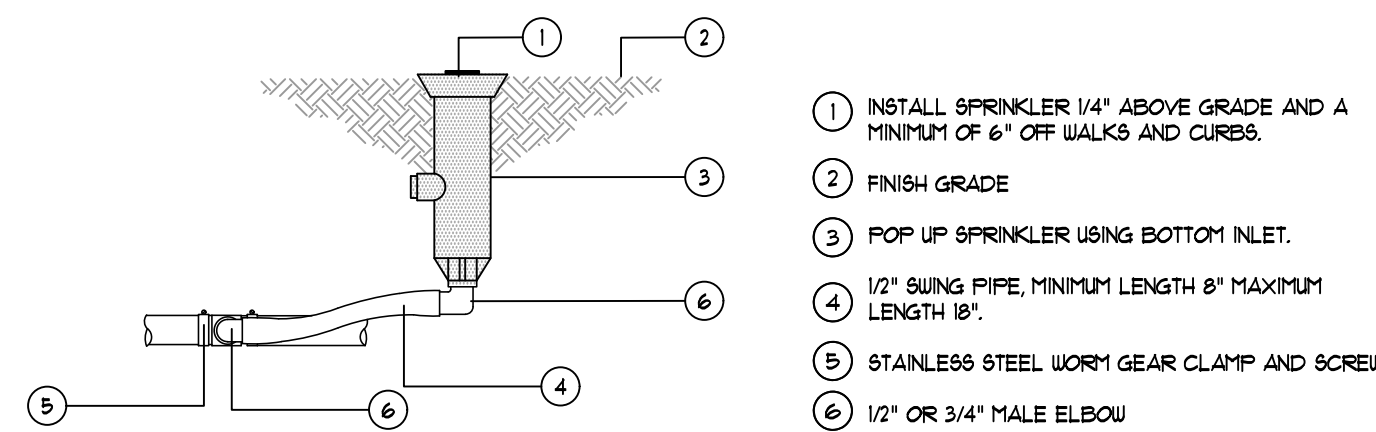

6 Two Elbow Swing Joint Detail
- NOT TO SCALE

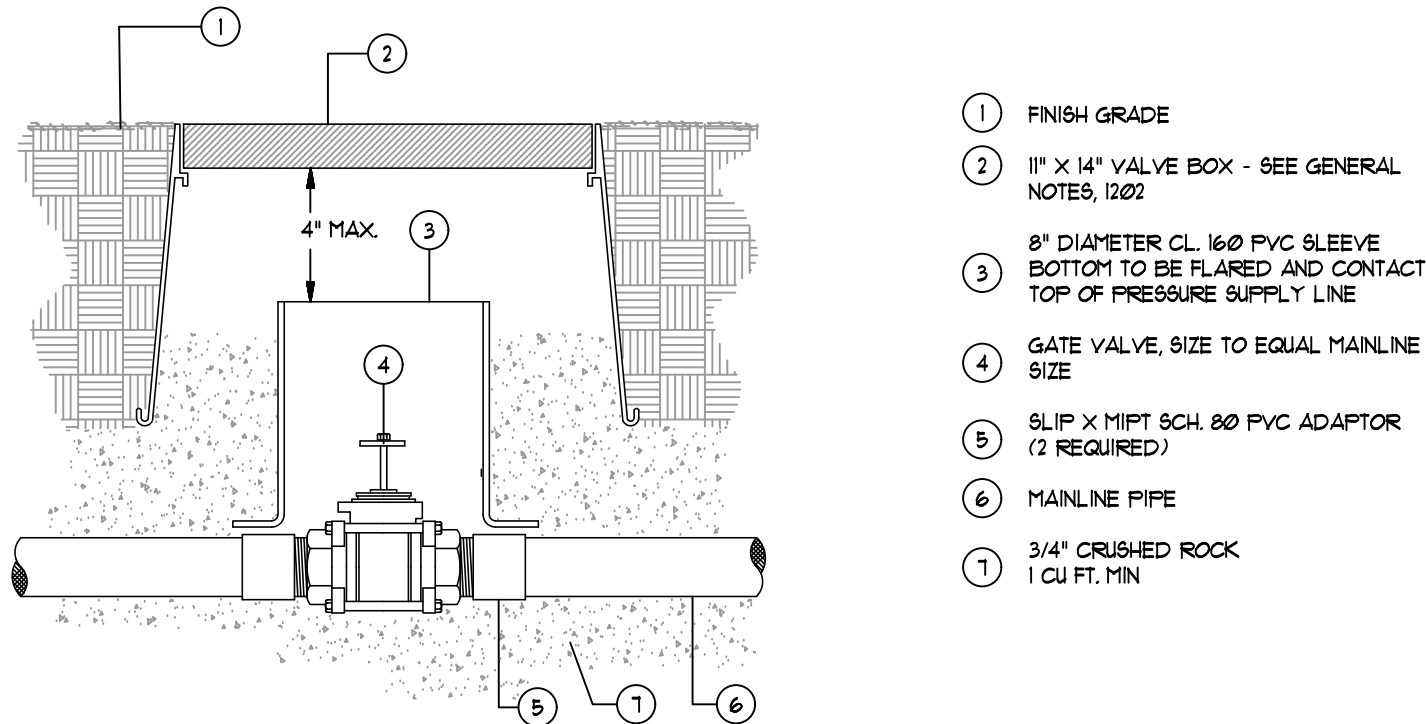

7 Isolation Valve
- NOT TO SCALE

IRRIGATION DETAILS
SCALE: AS NOTED

10/27/2026	ADDENDUM NO. 2
10/12/2026	BIDS AND PERMITS
09/25/2026	SITE PLAN REVIEW
09/21/2026	CD PEER REVIEW
09/09/2026	CD TEAM REVIEW

Drawn By	BBOUCHARD
Designer	PANDRIESE
Reviewer	PANDRIESE
Manager	CKRETOVIC

Hard copy is intended to be 24"x36" when plotted. Scale(s) indicated and graphic quality may not be accurate for any other size.


PROJECT NO.
2500281

SHEET NO.

L602


GENERAL ARCHITECTURAL ABBREVIATIONS			
ACM ACT ACP ADDL ADJ AFF AFG AGGR AHU AL ALT ALUM ANOD APPROX ARCH ASPH AVG	ALUMINUM COMPOSITE MATERIAL ACOUSTICAL CEILING TILE ADJUSTABLE ABOVE FINISH FLOOR ABOVE FINISH GRADE AGGREGATE AIR HANDLING UNIT ALUMINUM ALTERNATE ALUMINUM ANODIZED APPROXIMATE (LY) ARCHITECT (URAL) ASPHALT AVERAGE	FT FTG FURN	FOOT, FEET FOOTING FURNITURE
BD BF BITUM BLDG BM BO BOS BOT BRG BSMT BTWN BUR	BOARD BARRIER FREE BITUMINOUS BUILDING BENCHMARK BOTTOM BOTTOM OF STEEL BOTTOM BEARING BASEMENT BETWEEN BUILT UP ROOFING	H HB HC HD HDW HDWD HM HORIZ HPT HR HT HVAC	HEIGHT, HIGH HOSE BIB HOLLOW CORE HEAD HARDWARE HARDWOOD HOLLOW METAL HORIZONTAL HIGH POINT HOUR HEIGHT HEATING-VENTILATION-AIR CONDITIONING HOT WATER
CAB CB CCTV CEM CER CFCI	CABINET CATCH BASIN CLOSED CIRCUIT TELEVISION CEMENT, CEMENTITIOUS CERAMIC CONTRACTOR FURNISHED- CONTRACTOR INSTALLED CONTRACTOR FURNISHED- OWNER INSTALLED	HW ID IMP IN INCAND INCL INFO INSUL INT INV	CABINET INSIDE DIAMETER INSULATED METAL PANEL INCH (ES) INCANDESCENT INCLUDE, INCLUDING INFORMATION INSULATION INTERIOR INVERT
CG CI CJ CL CLG CLR CMU COL CONC CONF CONN CONSTR CONT CONTR CORR CPT CR CSK CT CU CW	CORNER GUARD CAST IRON CONTROL JOINT CENTER LINE CEILING CLEAR CONCRETE MASONRY UNIT COLUMN CONCRETE CONFERENCE CONNECTION CONSTRUCTION CONTINUOUS CONTRACTOR CORRUGATED CARPET CARD READER COUNTERSUNK CERAMIC TILE CUBIC COLD WATER	JAN JC JT JST JT KG KIT KM KPL L LAB LAM LAV LB LED LH LIN LL LLH LLV LP LT LT WT LTS LVL LVR	JANITOR JANITOR'S CLOSET JOIST JOINT KILOGRAM KITCHEN KILOMETER KICK PLATE LENGTH, LONG LABORATORY LAMINATE, LAMINATION LAVATORY POUND LIGHT-EMITTING DIODE LINEAR FOOT LEFT HAND LINEAR LEAD LINED LONG LEG HORIZONTAL LONG LEG VERTICAL LOW POINT LIGHT LIGHT WEIGHT LIGHTING DEPARTMENT DETAIL DRINKING FOUNTAIN DIAMETER DIAGONAL DIFFUSER DIMENSION DISPENSER DOWN DOWNSPOUT DISHWASHER DRAWING DRAWINGS
EA EC EF EG EIFS EJ EL ELAST ELEC ELEV EMER ENCL EOS EP EPB EPDM	EACH END CAP EXHAUST FAN EDGE GUARD EXTERIOR INSULATION FINISH SYSTEM EXPANSION JOINT ELEVATION ELASTOMERIC ELECTRICAL ELEVATOR EMERGENCY ENCLOSURE EDGE OF SLAB ELECTRICAL PANEL ELECTRICAL PANEL BOARD ETHYLENE PROPYLENE DIENE MONOMER	M MATL MAX MISC MFR MH MIN MISC MM MO MOD MTD MOUNT MULL	METERS MATERIAL MAXIMUM MEDIUM DENSITY FIBERBOARD MEDIUM DENSITY OVERLAY MECHANICAL MEDIUM MEMBRANE MEZZANINE MANUFACTURING MANUFACTURER MANHOLE MINIMUM MISCELLANEOUS MILLIMETERS MASONRY OPENING MODULE, MODULAR MOUNTED MOUNTING MULLION
EQ EQ SP EQUIP EQUIV ESCAL EST EWC EX EXCAV EXH EXIST EXP EXT	EQUAL EQUALLY SPACED EQUIPMENT EQUIVALENT ESCALATOR ESTIMATE (D) ELECTRIC WATER COOLER EXISTING EXCAVATED EXHAUST EXISTING EXPANSION EXTERIOR	NTS NW OA OC OD OFCI OFOI OH OPP ORD OVHD OZ	NOT APPLICABLE NORTHWEST OVERALL ON CENTER OUTSIDE DIAMETER OWNER FURNISHED- CONTRACTOR INSTALLED OWNER FURNISHED- OWNER INSTALLED OVERHEAD OPPOSITE OVERFLOW ROOF DRAIN OVERHEAD OUNCE
F/F FA FAS FCU FD FDC FEC FE FF FF&E FFE FFU FHC FXT FLAM FLASH FLEX FLUOR FNDN FO FP FRP FRT	FACE TO FACE FIRE ALARM FIRE ALARM STATION FAN COIL UNIT FLOOR DRAIN FIRE DEPARTMENT CONNECTION FIRE EXTINGUISHER CABINET FIRE EXTINGUISHER FINISH FACE FURNITURE, FIXTURES & EQUIPMENT FINISH FLOOR ELEVATION FAN FILTER UNIT FIRE HOSE CABINET FIXTURE FLAMABLE FLASHING FLEXIBLE FLUORESCENT FOUNDATION FACE OF FIRE PROTECTION FIBER REINFORCED PLASTIC FIRE RETARDANT TREATED	PA PART PBD PCF PCI PEMB PERF PERIM PERM PERP PL PLAM PLF PLUMB PLYWD PNL PNL BD PT	PUBLIC ADDRESS PARTIAL PARTICLEBOARD POUNDS PER CUBIC FOOT POUNDS PER CUBIC INCH PRE-ENGINEERED METAL BUILDING PERFORATED PERIMETER PERMEABLE PERPENDICULAR PLATE PLASTIC LAMINATE POUNDS PER LINEAR FOOT PLYWOOD PANEL BOARD PAINT
PORT PP PR PREFAB PREP PREP PROC PROJ PROP REFR PSI PTN PVC PVC PAVING PMT PWR	PORTABLE PUSH PLATE PAIR PREFABRICATED PREPARATION PARKING PROCESS PROJECT PROPERTY POUNDS PER SQUARE FOOT POUNDS PER SQUARE INCH PARTITION POLYVINYL CHLORIDE GLAZING GRADE, GRADING GYPSUM BOARD	PORT PP PR PREFAB PREP PREP PROC PROJ PROP REFR PSI PTN PVC PVC PAVING PMT PWR	PORTABLE PUSH PLATE PAIR PREFABRICATED PREPARATION PARKING PROCESS PROJECT PROPERTY POUNDS PER SQUARE FOOT POUNDS PER SQUARE INCH PARTITION POLYVINYL CHLORIDE GLAZING GRADE, GRADING GYPSUM BOARD
QT QTR QTY	QUARRY TILE QUARTER QUANTITY	QT QTR QTY	QUARRY TILE QUARTER QUANTITY
R RA RAD RB RCP RCPT RD RECT REF REFR REG REINF REQD REQT RESIL RESIL RET REV RF RH RM RND RO ROW	RISER RETURN AIR RADIUS RESILIENT/RUBBER BASE REFLECTED CEILING PLAN RECEPTACLE ROOF DRAIN RECTANGULAR REFERENCE REFRIGERATOR REGISTER REINFORCE (D) (ING) (MENT) REQUIRED REQUIREMENT RESILIENT RETURN REVISION RESILIENT FLOORING RIGHT HAND ROOM ROUND ROUGH OPENING RIGHT OF WAY	R RA RAD RB RCP RCPT RD RECT REF REFR REG REINF REQD REQT RESIL RESIL RET REV RF RH RM RND RO ROW	RISER RETURN AIR RADIUS RESILIENT/RUBBER BASE REFLECTED CEILING PLAN RECEPTACLE ROOF DRAIN RECTANGULAR REFERENCE REFRIGERATOR REGISTER REINFORCE (D) (ING) (MENT) REQUIRED REQUIREMENT RESILIENT RETURN REVISION RESILIENT FLOORING RIGHT HAND ROOM ROUND ROUGH OPENING RIGHT OF WAY
SA SB SC SCHED SD SE SECT SEG SEP SEP JT SHGC SHT SHV SHWR SHM SP SPEC SPKLR SPKR SQ SS SSK SSM ST STAG STC STD STEEL STOR STRUCT SUSP SUSP CLG SW SYM SYST	SUPPLY AIR SPLASH BLOCK SOLID CORE SCHEDULE STORM DRAIN SOUTHEAST SECTION SEGMENT SEPARATION, SEPARATE SEPARATION JOINT SOLAR HEAT GAIN COEFFICIENT SHEET, SHEETING SHELVES, SHELVING SHOWER SIMILAR SPACE, SPACED, SPACING SPECIFICATION SPRINKLER SPEAKER SQUARE STAINLESS STEEL SERVICE SINK SOLID SURFACE MATERIAL STREET STAGGERED SOUND TRANSMISSION COEFFICIENT STANDARD STEEL STORAGE STRUCTURAL SUSPENDED SUSPENDED CEILING SOUTHWEST SYMMETRICAL SYSTEM	SA SB SC SCHED SD SE SECT SEG SEP SEP JT SHGC SHT SHV SHWR SHM SP SPEC SPKLR SPKR SQ SS SSK SSM ST STAG STC STD STEEL STOR STRUCT SUSP SUSP CLG SW SYM SYST	SUPPLY AIR SPLASH BLOCK SOLID CORE SCHEDULE STORM DRAIN SOUTHEAST SECTION SEGMENT SEPARATION, SEPARATE SEPARATION JOINT SOLAR HEAT GAIN COEFFICIENT SHEET, SHEETING SHELVES, SHELVING SHOWER SIMILAR SPACE, SPACED, SPACING SPECIFICATION SPRINKLER SPEAKER SQUARE STAINLESS STEEL SERVICE SINK SOLID SURFACE MATERIAL STREET STAGGERED SOUND TRANSMISSION COEFFICIENT STANDARD STEEL STORAGE STRUCTURAL SUSPENDED SUSPENDED CEILING SOUTHWEST SYMMETRICAL SYSTEM
TAB TAG TAN TD TELEPH TEMP TEMP GL THERM THK THR THRU TO TOC TOR TOS TOT TOW TP TPO TR TV TYP	TOP AND BOTTOM TONGUE AND GROOVE TANGENT TRENCH DRAIN TELEPHONE TEMPORARY TEMPERED GLASS THERMAL THICK (NESS) THRESHOLD THROUGH TOP OF TOP OF CONCRETE, TOP OF CURB TOP OF RAILING TOP OF STEEL TOTAL TOP OF WALL TOP OF PAVEMENT THERMOPLASTIC POLYOLEFIN TREAD TELEVISION TYPICAL	TAB TAG TAN TD TELEPH TEMP TEMP GL THERM THK THR THRU TO TOC TOR TOS TOT TOW TP TPO TR TV TYP	TOP AND BOTTOM TONGUE AND GROOVE TANGENT TRENCH DRAIN TELEPHONE TEMPORARY TEMPERED GLASS THERMAL THICK (NESS) THRESHOLD THROUGH TOP OF TOP OF CONCRETE, TOP OF CURB TOP OF RAILING TOP OF STEEL TOTAL TOP OF WALL TOP OF PAVEMENT THERMOPLASTIC POLYOLEFIN TREAD TELEVISION TYPICAL
UC UL UNO UTIL	UNDER COUNTER UNDERWRITERS LABORATORIES UNLESS OTHERWISE NOTED UTILITY	UC UL UNO UTIL	UNDER COUNTER UNDERWRITERS LABORATORIES UNLESS OTHERWISE NOTED UTILITY
VAC VCT VERT VEST VIF VOL VTR VWC	VACUUM VINYL COMPOSITION TILE VERTICAL VESTIBULE VERIFY IN FIELD VOLUME VENT THROUGH ROOF VINYL WALL COVERING	VAC VCT VERT VEST VIF VOL VTR VWC	VACUUM VINYL COMPOSITION TILE VERTICAL VESTIBULE VERIFY IN FIELD VOLUME VENT THROUGH ROOF VINYL WALL COVERING
W/ W/C W/O W/W WC WOOD WH WLCHR WM WR WGT WTHPRF WTRPRF WWF WWM	WITH WATER CLOSET WITHOUT WALL TO WALL WALL COVERING WOOD WATER HEATER WHEELCHAIR WIRE MESH WATER RESISTANT WEIGHT WEATHERPROOF WATERPROOF WELODED WIRE FABRIC WELODED WIRE MESH	W/ W/C W/O W/W WC WOOD WH WLCHR WM WR WGT WTHPRF WTRPRF WWF WWM	WITH WATER CLOSET WITHOUT WALL TO WALL WALL COVERING WOOD WATER HEATER WHEELCHAIR WIRE MESH WATER RESISTANT WEIGHT WEATHERPROOF WATERPROOF WELODED WIRE FABRIC WELODED WIRE MESH
YD	YARD	YD	YARD

ACCESSIBILITY DETAILS (BASED ON ICC/ANSI A117.1, 2017)


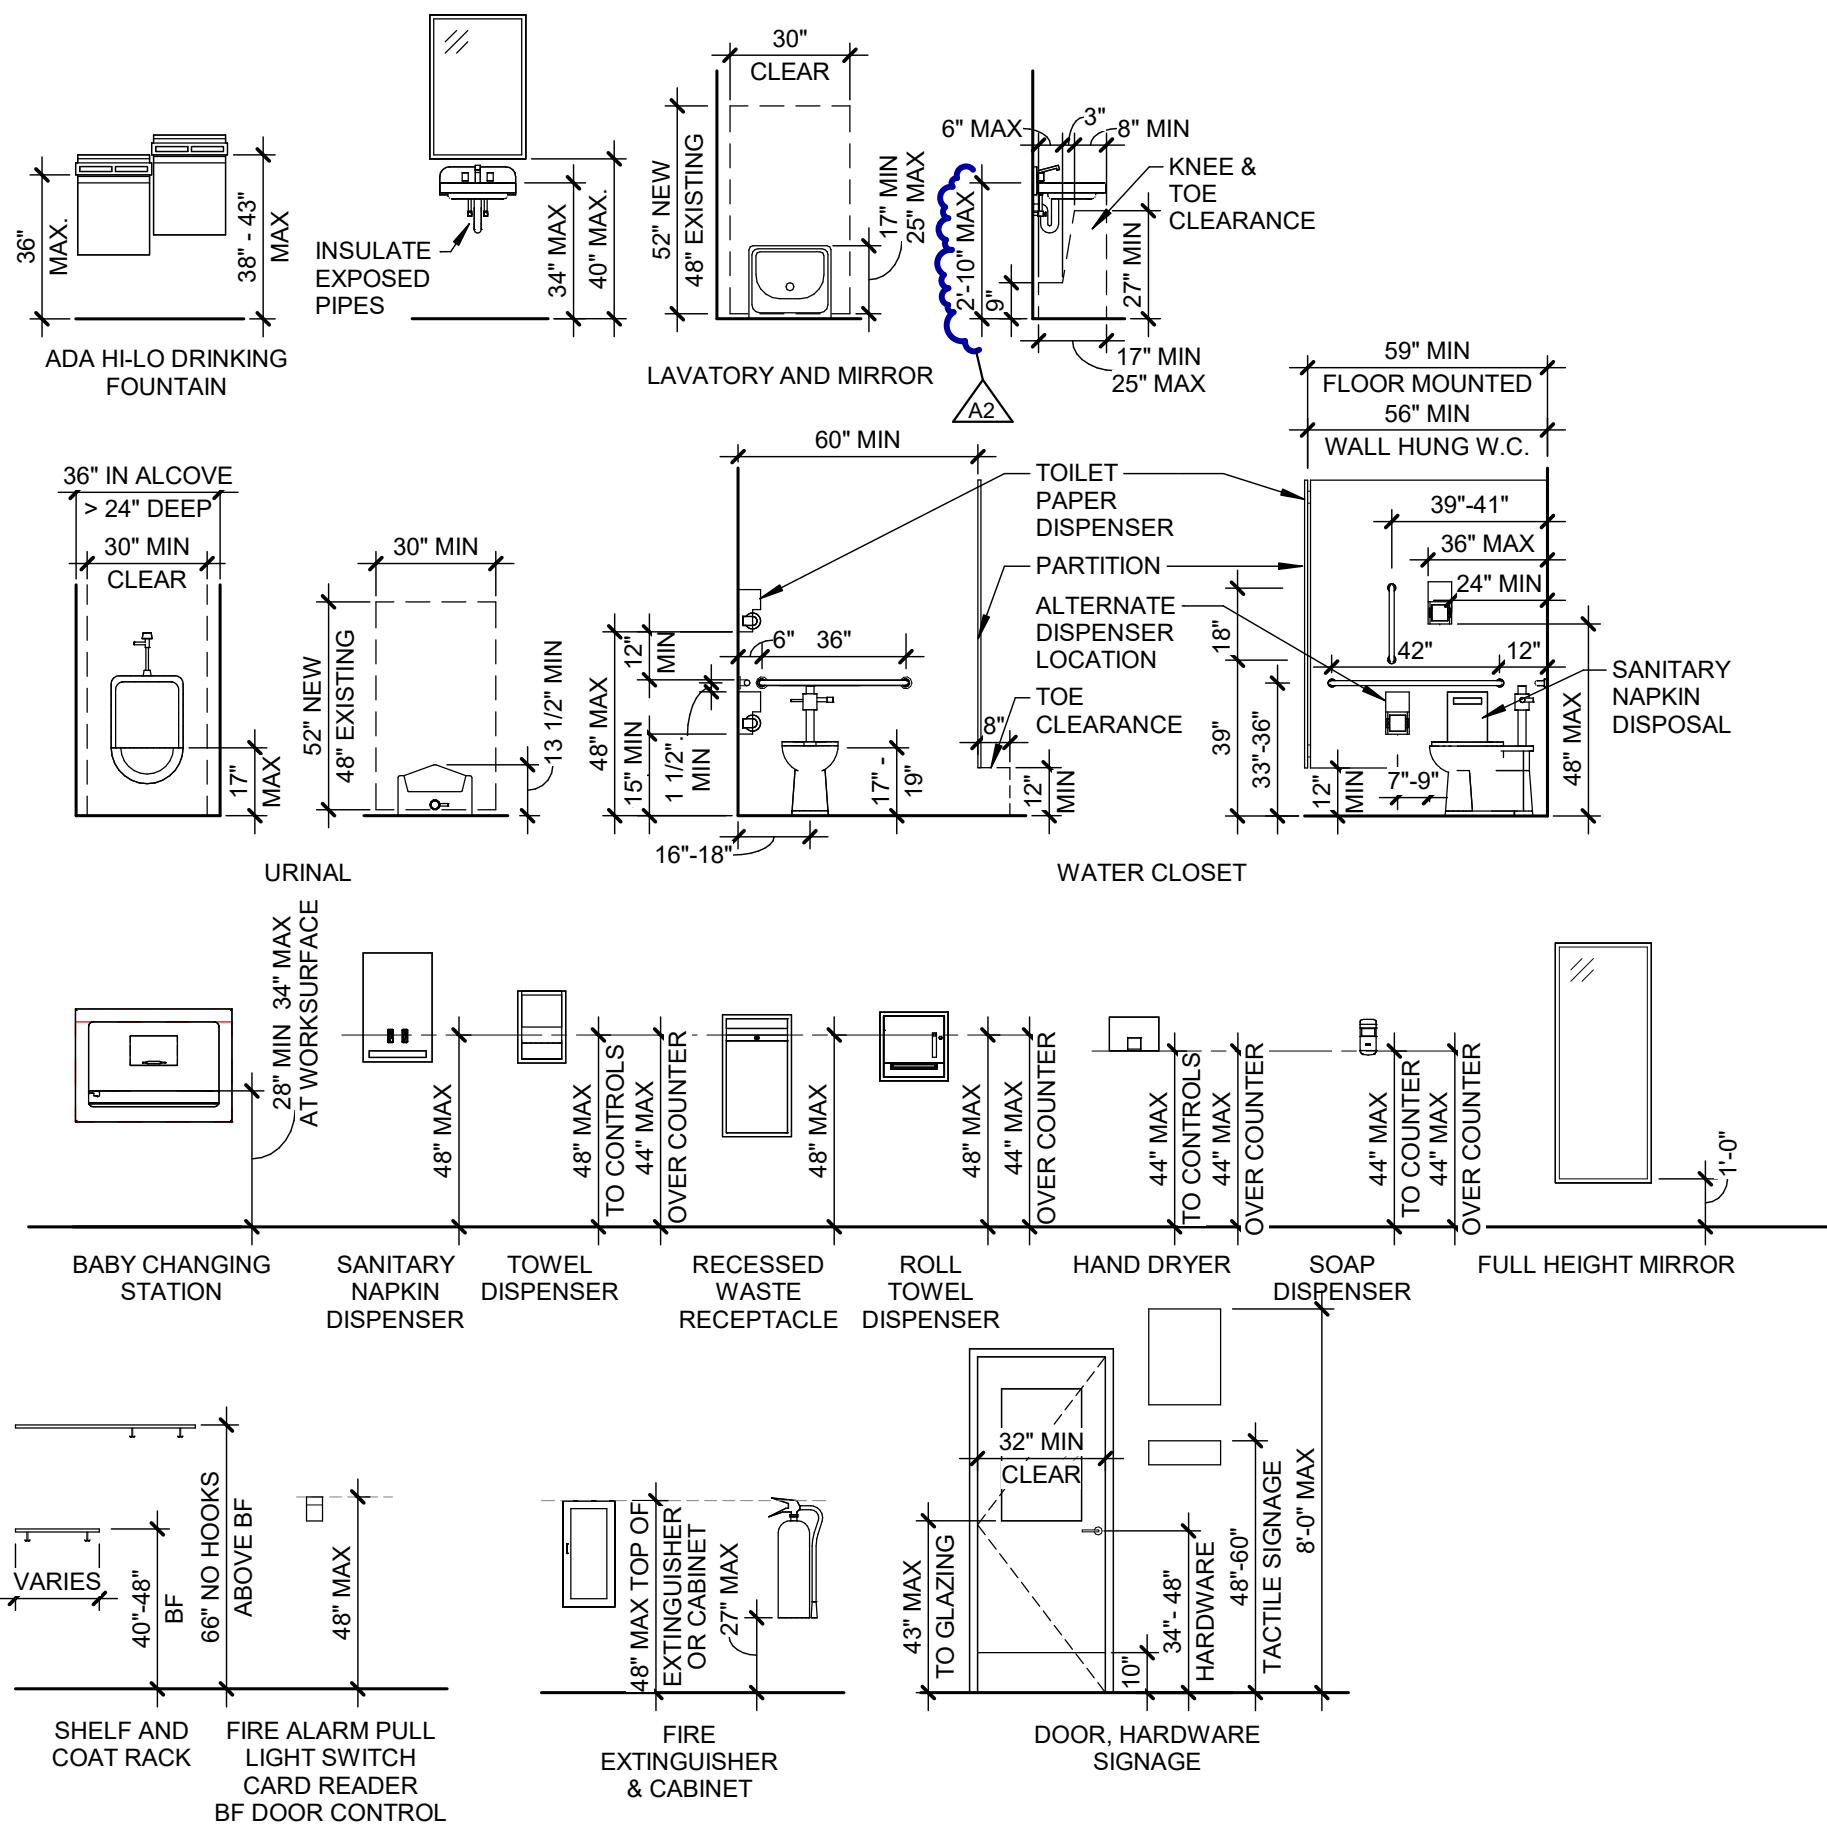


MATERIALS LEGEND

PLAN AND SECTION

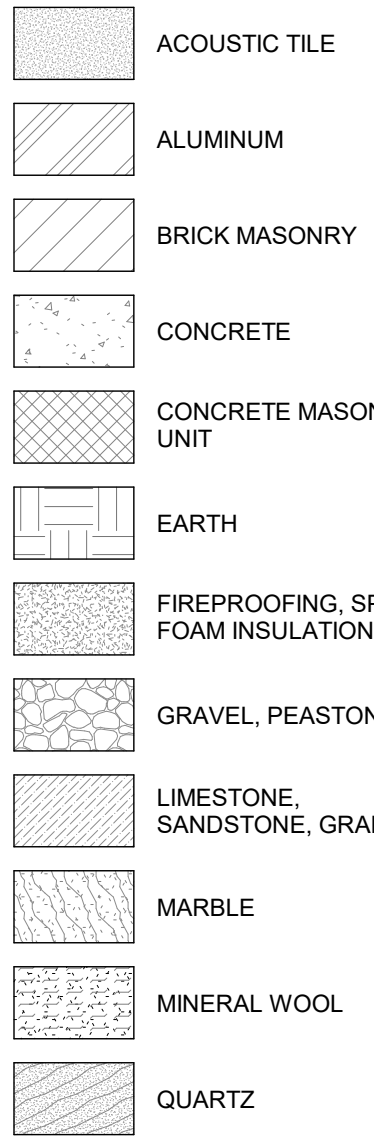


ELEVATION

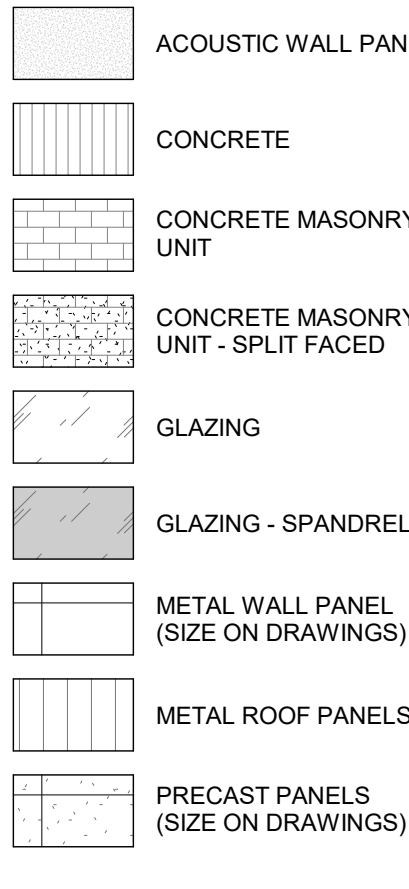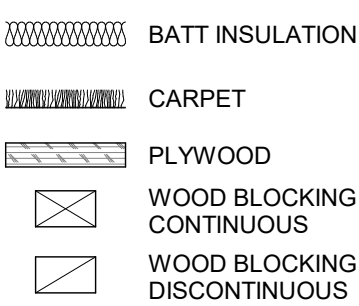


FIRE SPRINKLER LOCATION LEGEND


SPRINKLER HEAD LOCATION IN GYPSUM BOARD CEILINGS

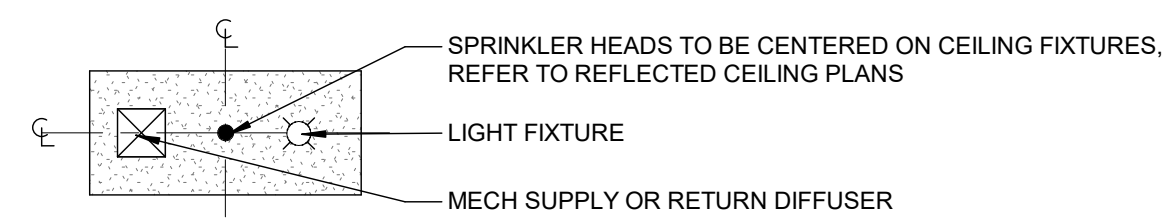


SPRINKLER HEAD LOCATION IN LINEAR METAL CEILINGS

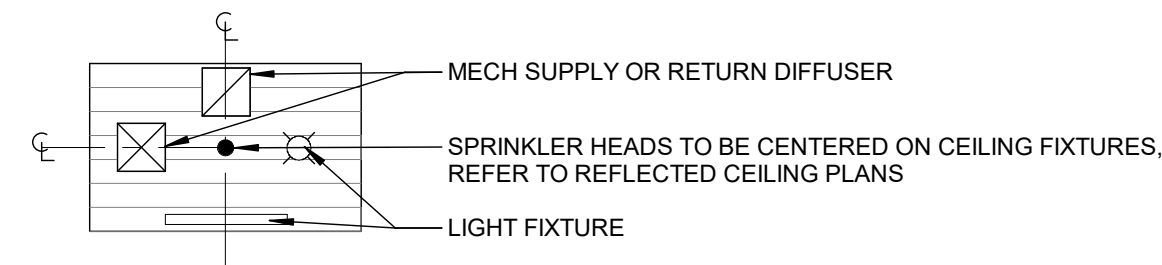


SPRINKLER HEAD LOCATION IN ACP CEILING

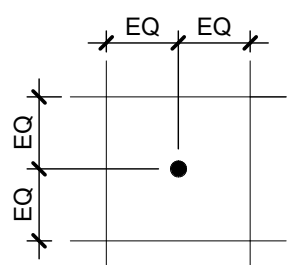


FLOOR PLAN SYMBOL LEGEND

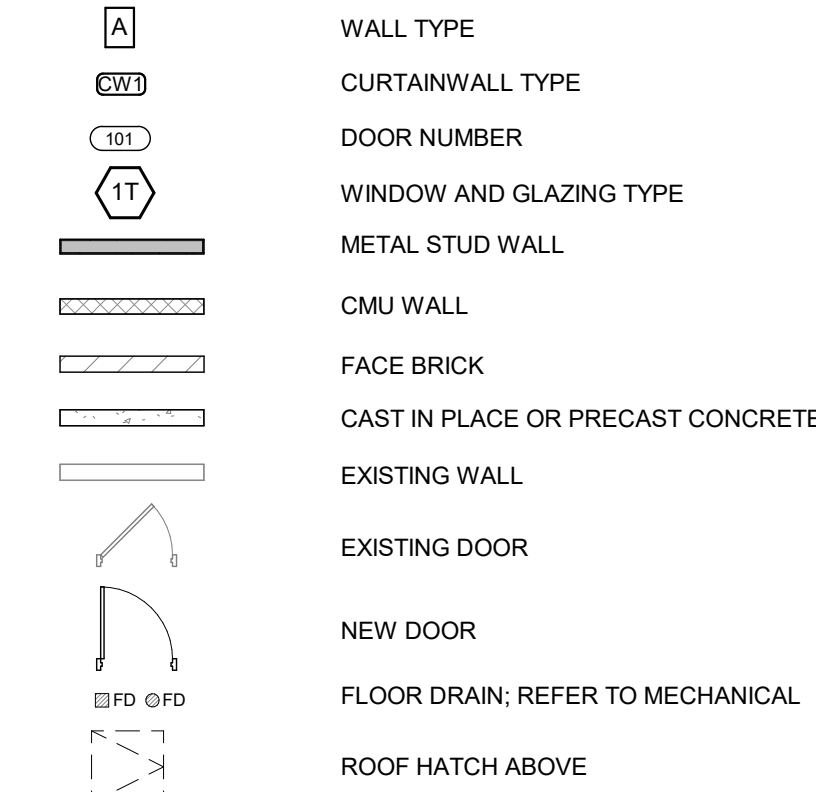


REFLECTED CEILING PLAN SYMBOL LEGEND

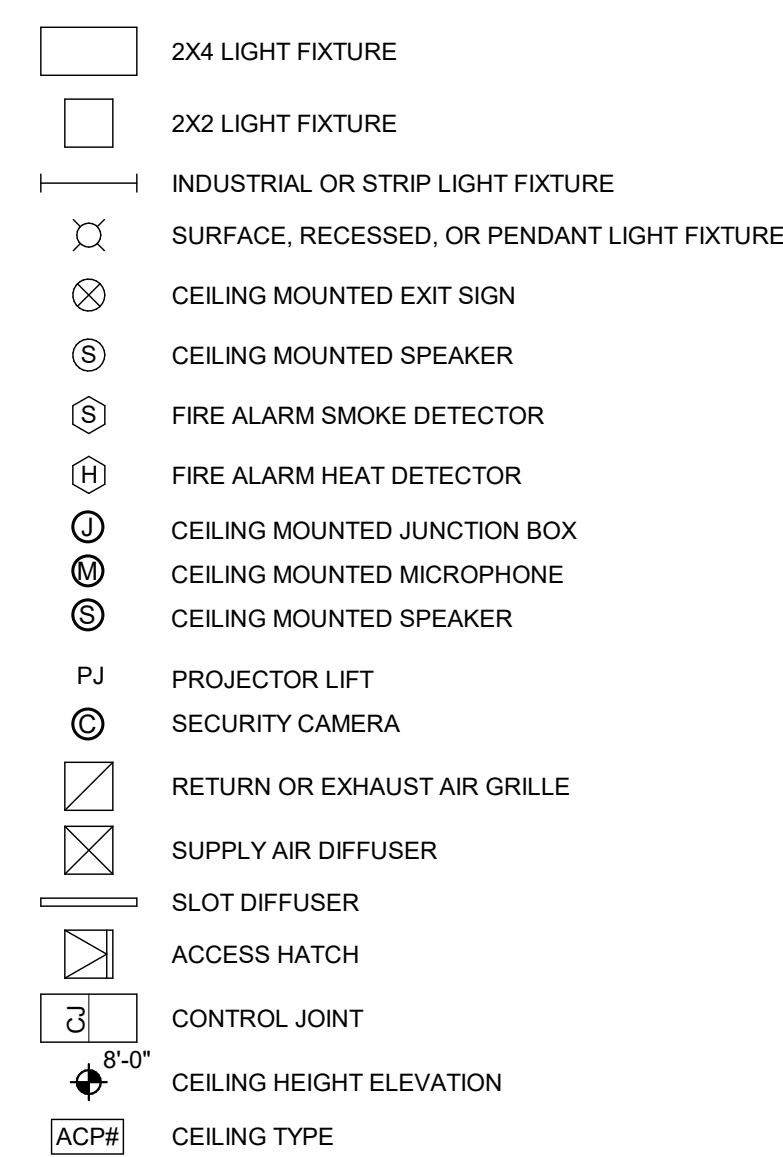


ROOF PLAN SYMBOL LEGEND

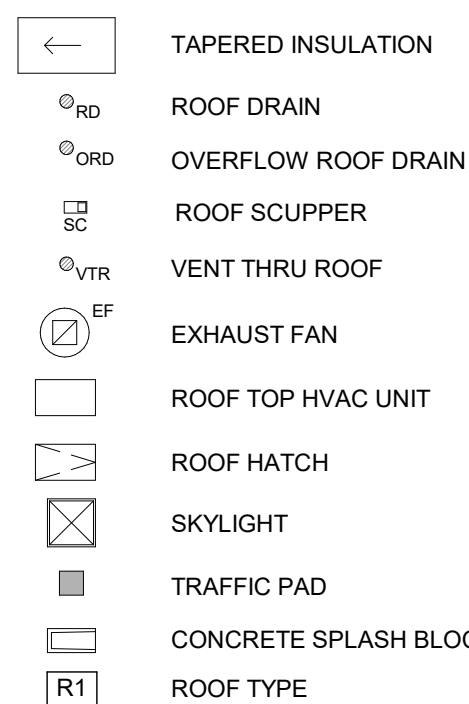

ELEVATION SYMBOL LEGEND

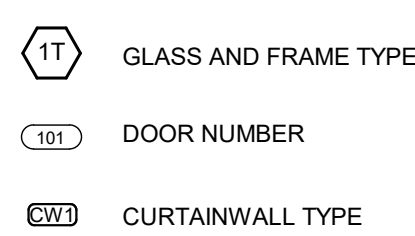


FINISH SYMBOL LEGEND

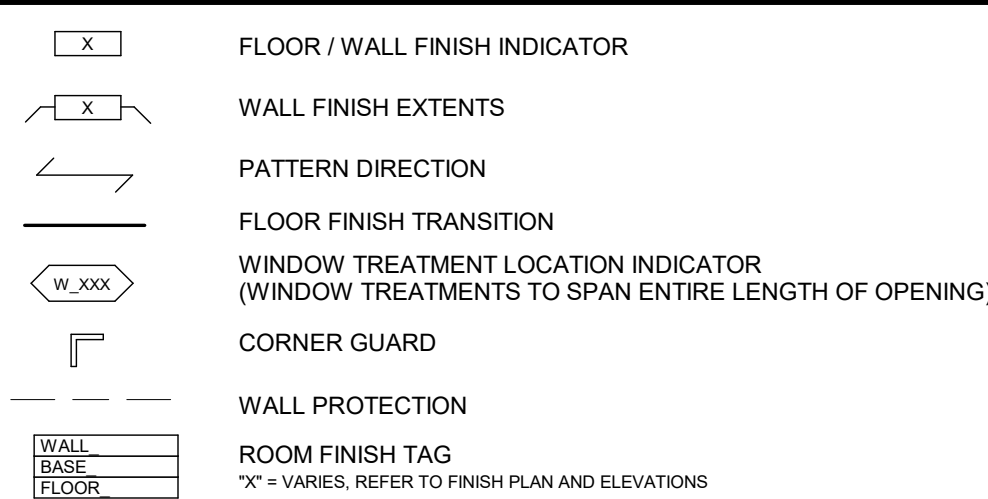

GENERAL NOTES

- THE FOLLOWING GENERAL NOTES APPLY TO ARCHITECTURAL SHEETS. NOT ALL NOTES BELOW NECESSARILY APPLY TO THIS PROJECT.
- COORDINATE ALL WORK INDICATED PER THE PROJECT MANUAL AND DRAWINGS - NOTE: THE MOST STRINGENT REQUIREMENT OR MORE COSTLY WORK SHALL GOVERN WHERE CONFLICTS OCCUR.
 - IF EXISTING CONDITIONS DIFFER FROM WHAT IS SHOWN, NOTIFY THE ARCHITECT IMMEDIATELY SO THE DESIGN MAY BE PROPERLY MODIFIED.
 - COORDINATE PHASING AND SEQUENCING OF THE WORK TO MAINTAIN CONTINUING OPERATION, BUILDING SECURITY AND WEATHER TIGHTNESS.
 - COORDINATE ALL CUT, PATCH, AND REPAIR WORK WITH ALL OTHER TRADES, INCLUDING MECHANICAL AND ELECTRICAL DRAWINGS. PATCHING OF FINISHES TO EXTEND TO NEAREST NATURAL BREAK OR SURFACE TERMINATION FOR A CLEAN, UNBLEMISHED APPEARANCE AT THE END OF CONSTRUCTION.
 - PROVIDE INTERIOR AND/OR EXTERIOR SHORING, BRACING, OR SUPPORT AS REQUIRED TO PREVENT MOVEMENT, SETTLEMENT, OR DAMAGE OF THE STRUCTURE WHERE WORK OCCURS.
 - VERIFY ALL DIMENSIONS INDICATED ON DRAWINGS PRIOR TO CONSTRUCTION; COMMENCEMENT OF WORK CONSTITUTES ACCEPTANCE OF CONDITIONS.
 - IF THE WORK RENOVATES AN EXISTING BUILDING AND AREAS WITHIN THE BUILDING ARE TO REMAIN OCCUPIED, PROVIDE AND MAINTAIN CONSTRUCTION BARRIER BETWEEN CONSTRUCTION AND OCCUPIED AREA.
 - REFER TO REFLECTED CEILING PLANS FOR CEILING HEIGHTS. ALL CEILING ELEVATIONS ARE ABOVE FINISH FLOOR.
 - ALL DIMENSIONS ON DRAWINGS ARE SHOWN TO FINISHED FACE OF WALL, FLOOR, OR CEILING, UNLESS OTHERWISE NOTED. REFER TO ENLARGED FLOOR PLANS, SECTIONS, AND DETAILS FOR OTHER DIMENSIONS.
 - REFER TO ROOM FINISH SCHEDULE. ELEVATIONS, REFLECTED CEILING PLAN AND FLOOR FINISH PLANS FOR FINISHES.
 - EXTEND ALL WALLS TIGHT TO DECK ABOVE, UNLESS NOTED OTHERWISE.
 - TOP OF SIDEWALKS (INCLUDING PAVEMENT PEDESTAL SYSTEM) OUTSIDE OF EXIT DOORS TO BE HELD 1/4" BELOW FINISHED FLOOR.
 - REFER TO STRUCTURAL DRAWINGS FOR ALL STEEL SHAPES AND SIZES.
 - SLOPE FLOORS TO FLOOR DRAINS. REFER TO ARCHITECTURAL AND STRUCTURAL DRAWINGS FOR ADDITIONAL INFORMATION.
 - MECHANICAL AND ELECTRICAL FIXTURES ARE SHOWN FOR REFERENCE AND COORDINATION ONLY. REFER TO MECHANICAL AND ELECTRICAL DRAWINGS FOR TYPES, LOCATIONS AND QUANTITIES REQUIRED.
 - REFER TO MECHANICAL, PLUMBING, AND ELECTRICAL DRAWINGS FOR COMPLETE LISTING OF ALL PENETRATIONS, ROOF PENETRATIONS, AND ROOF TOP EQUIPMENT.
 - ALL BLOCKING / SHEATHING TO BE FIRE RETARDANT TREATED (FRT). IN INTERIOR WALLS SUCH AS FOR TOILET ACCESSORIES, HANDRAILS, MILLWORK, CABINETS, AND WINDOW AND DOOR FRAMES; OR AS OTHERWISE INDICATED.
 - ROOF SLOPE TO BE 1/4:12 SLOPE MINIMUM. VERIFY ROOF DECK CONDITION AND COORDINATE ROOF SYSTEM INSTALLATION REQUIREMENTS PRIOR TO COMMENCING ROOFING WORK.
 - ALL ROOF SADDLES/CRICKETS TO BE 1/2:12 SLOPE MINIMUM.
 - PROVIDE ROOF TRAFFIC PADS AT ALL LANDING LOCATIONS ADJACENT TO ACCESS HATCHES, PORTABLE LADDER ACCESS POINTS, STAIRS, SURROUND FULLY AROUND ANY MECHANICAL EQUIPMENT, ADJACENT TO ANY TYPICAL POINTS OF MAINTENANCE (HOSE BIBBS, ELECTRICAL RECEPTACLES, ROOF LADDERS, EQUIPMENT PANELS, ETC).
 - COORDINATE INSTALLATION OF FLASHING TO PROVIDE CONTINUITY. END DAMS, AND TERMINATIONS THAT DIRECT MOISTURE OUT OF THE BUILDING; COORDINATE WITH BUILDING AIR / MOISTURE BARRIER SYSTEMS.
 - REFER TO VENDOR DRAWINGS (IF ANY) FOR ADDITIONAL INFORMATION TO COORDINATE INSTALLATION OF OWNER EQUIPMENT / SYSTEMS.
 - BUILDING FIRST FLOOR ELEVATION SHOWN AT 100'-0". ACTUAL BUILDING FIRST FLOOR ELEVATION: - LAKE HOUSE (USGS) ELEVATION 665.00'. - LAKE HALL (USGS) ELEVATION 668.50'.

STANDARD DETAILS

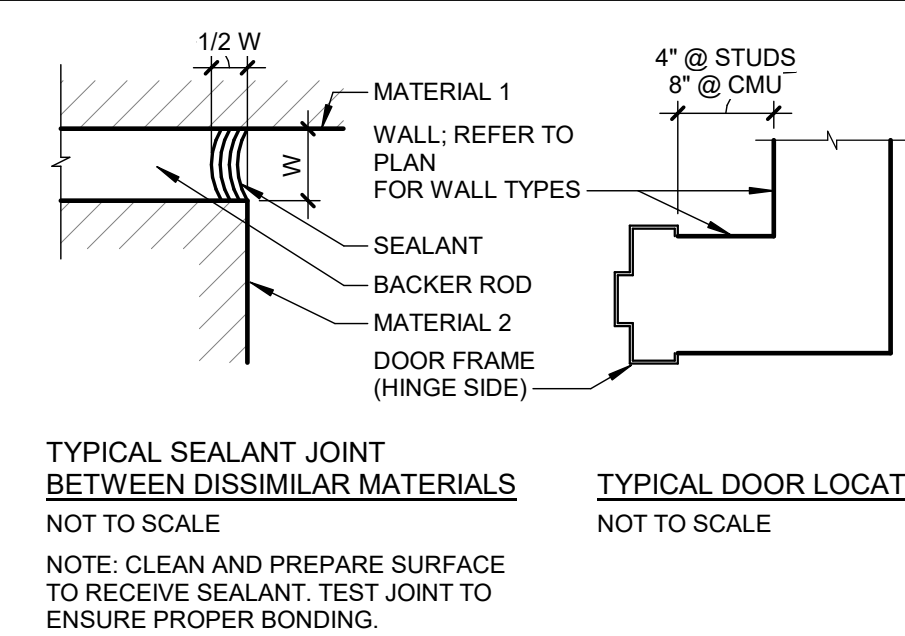


REVISIONS		
10/27/2026	A2	ADDENDUM NO. 2

10/12/2026	BIDS & PERMIT
09/21/2026	CD PEER REVIEW
09/09/2026	CD TEAM REVIEW
08/10/2026	CD 50% PROGRESS
08/22/2026	DD OWNER REVIEW
08/15/2026	DD PEER REVIEW
08/08/2026	DD 90 % PROGRESS
08/18/2026	DD 90 % PROGRESS
02/23/2026	SD OWNER REVIEW
02/13/2026	SD PEER REVIEW
02/09/2026	SD PROGRESS REVIEW

Drawn By IOLKHOVESKA
Designer IELHENNAWY
Reviewer WLRAPSON
Manager CKRETOVIC

PROJECT NO.
2500281
SHEET NO.

A001

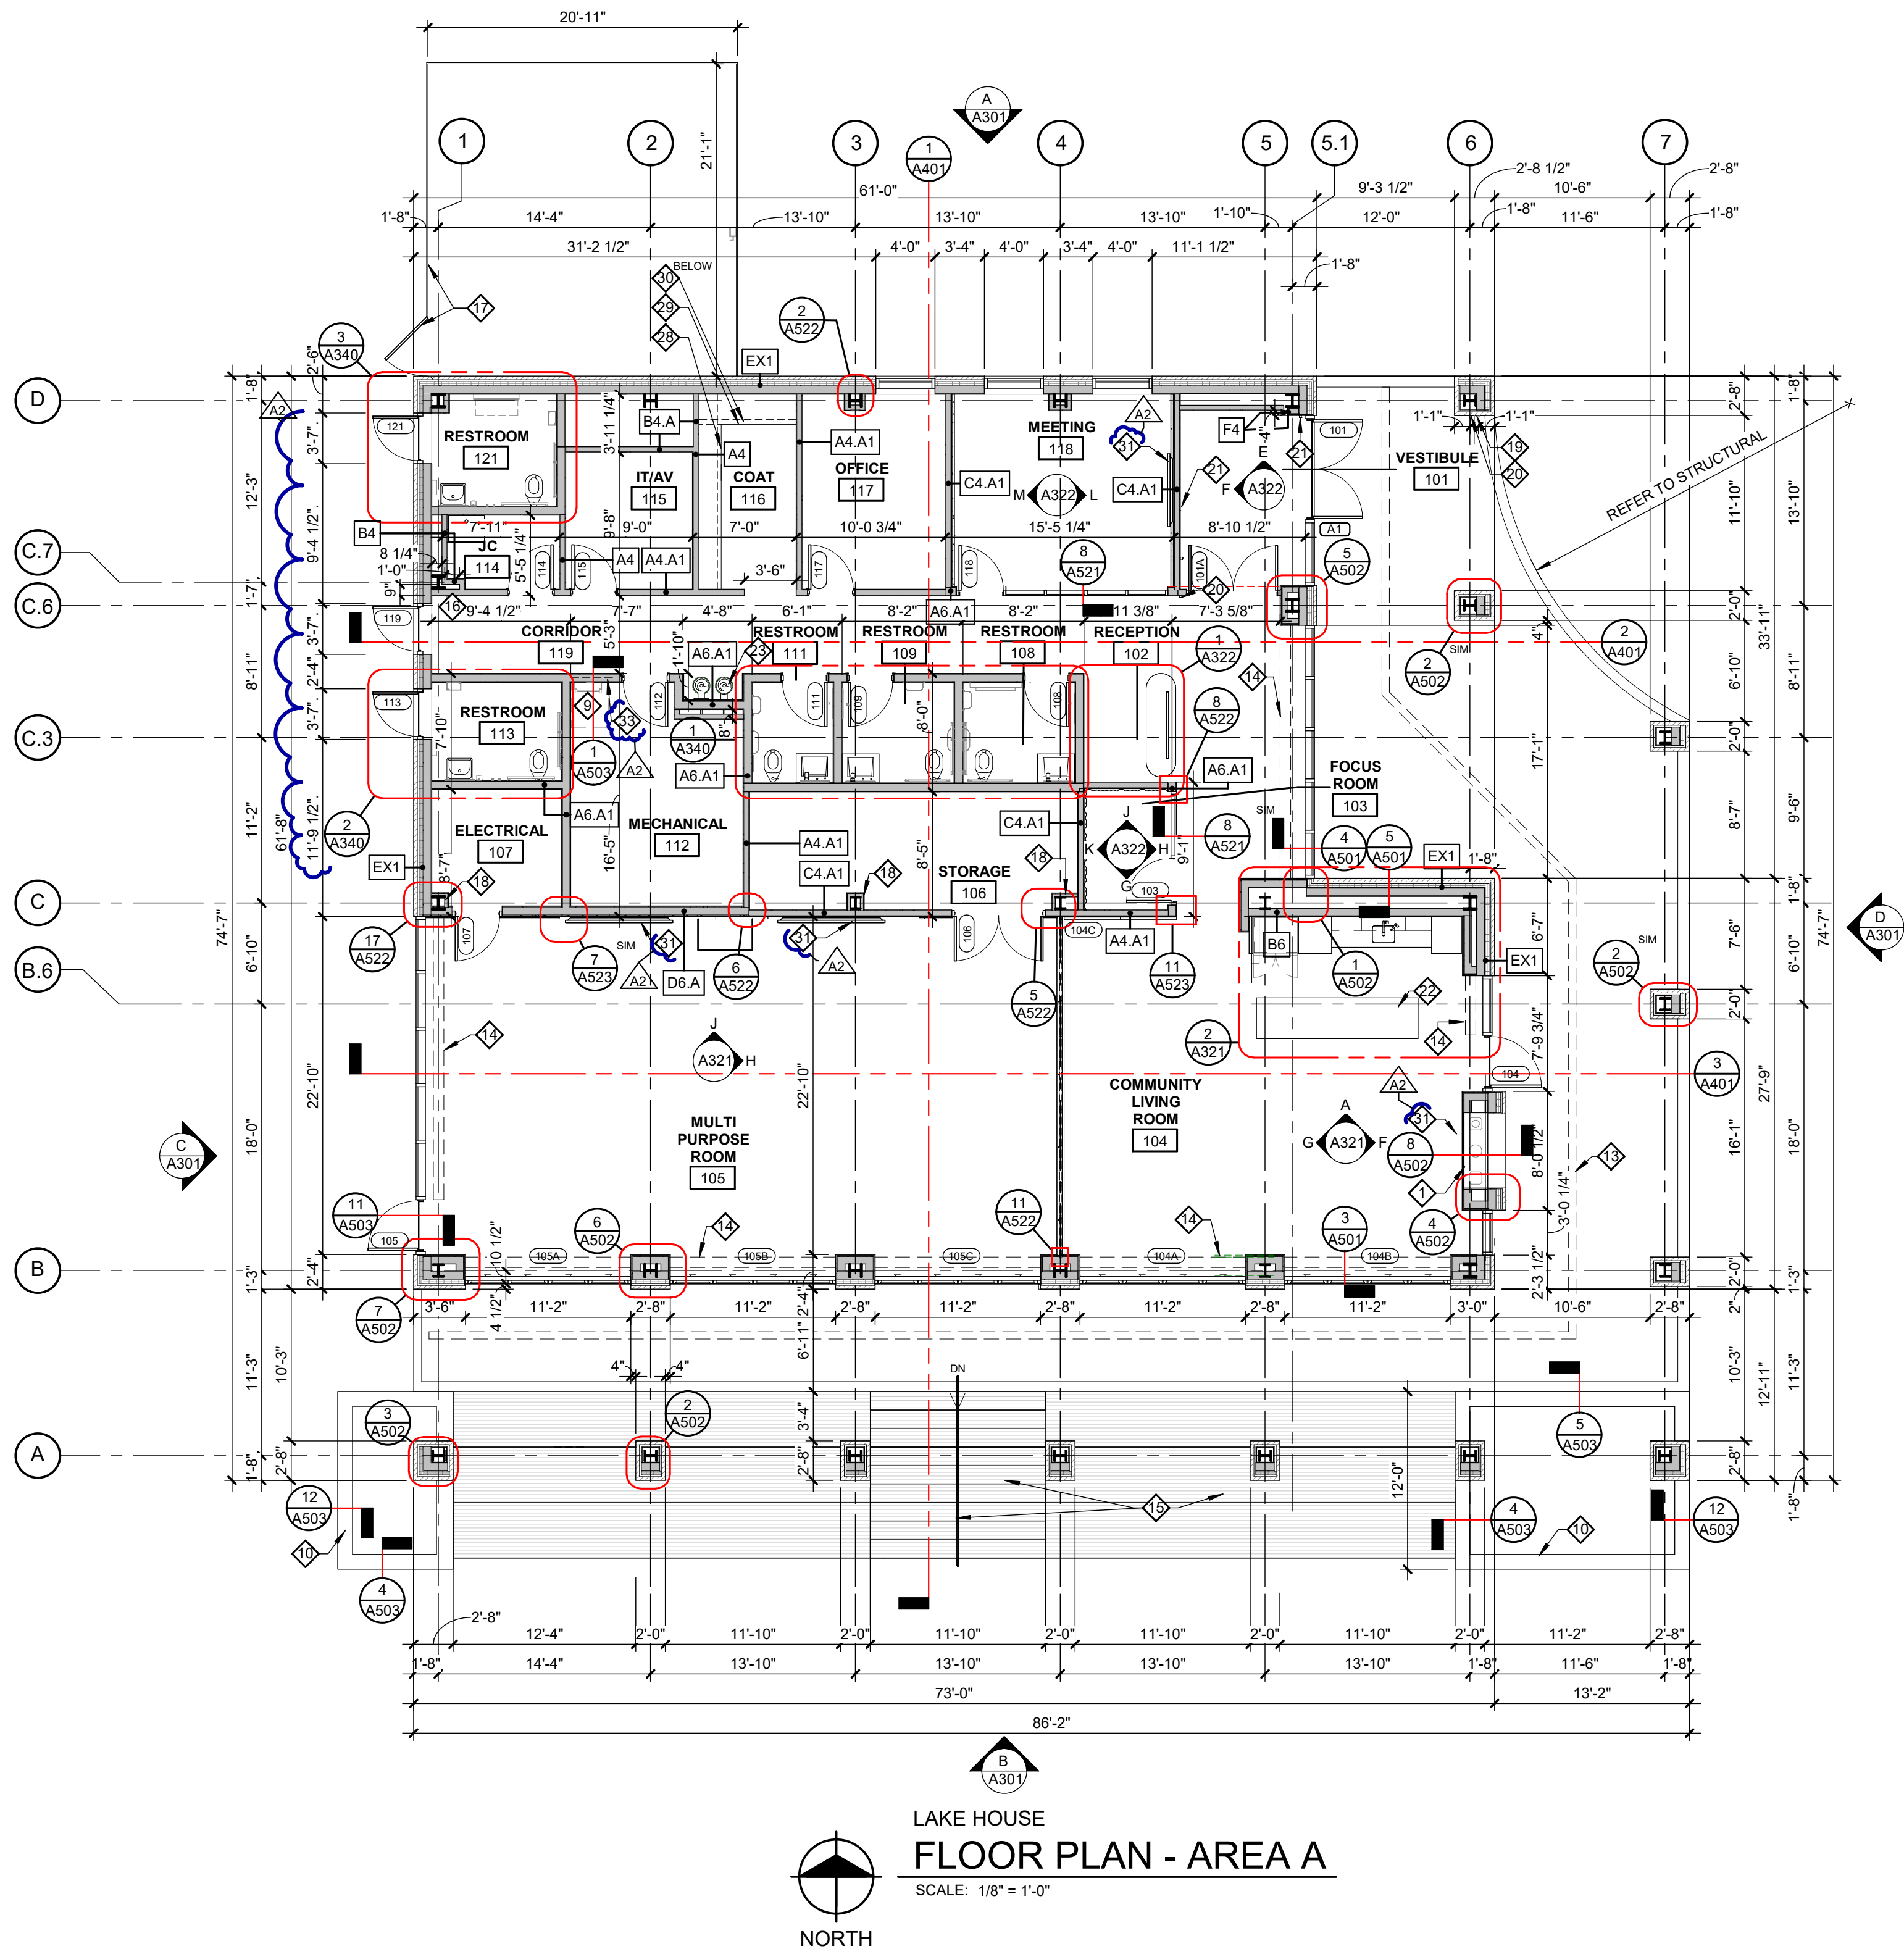

KEY NOTES

- CUSTOM VENTED SEE-THROUGH GAS FIREPLACE, REFER TO ELECT., MECH AND SPECS.; APPROX 5'W X 3'H
- SERVICE SINK REFER TO PLUMBING.
- OPEN TO STRUCTURE ABOVE.
- ROOF ACCESS LADDER AND HATCH DOOR ABOVE.
- ATTIC ACCESS HATCH WITH FOLD DOWN LADDER WITH FLAT LOWER / INTERIOR COVER
- KITCHEN SINK, REFER TO FOOD SERVICE AND PLUMBING.
- SOLID SURFACE BAR COUNTER (HIGH AND LOW) WITH BAR EQUIPMENT, REFER TO FOOD SERVICE DRAWINGS FOR BAR EQUIPMENT INFORMATION AND DETAILS.
- PROVIDE LEVEL 5 GYPSUM BOARD WALL FINISH ON ENTIRE LENGTH OF WALL.
- ROOF ACCESS LADDER AND HATCH DOOR ABOVE.
- ARCHITECTURAL PLANTER BOX REFER CIVIL AND STRUCTURAL FOR DETAILS
- SKYRING COLUMNS SEE SHEET A173 FOR DIMENSIONS
- 42-INCH HIGH PAINTED (SAFETY YELLOW) GUARDRAIL, TYPE HDRL-4, WITH 36" WIDE (CLEAR MIN.) SWING GATE.
- LINEAR DRAINS BELOW PEDESTAL PAVER SYSTEM, REFER TO CIVIL FOR DRAINS
- IN FLOOR MECHANICAL TRENCH, REFER TO MECHANICAL.
- TIERED SEATING, STAIRS, AND HANDRAIL; REFER TO CIVIL DRAWINGS FOR DETAIL
- FULLY-RECESSED FIRE EXTINGUISHER CABINET W/ EXTINGUISHER; PAINT TO MATCH ADJACENT WALL FINISH.
- MECHANICAL SCREEN WALLS AND GATE. MATERIAL AND CONSTRUCTION TO BE DETERMINED. REFER TO ELEVATIONS FOR HEIGHT
- 5/8" GYPSUM BOARD ON 2-1/2" METAL STUD FRAMING; PROVIDE TIGHT-FITTING ENCLOSURE AROUND COLUMN.
- CARD READER: 42" A.F.F. TO CENTERLINE.
- ACTUATOR BUTTON OPERATOR: 42" A.F.F. TO CENTERLINE.
- ROUGH-IN FOR FUTURE ACTUATOR BUTTON: 42" A.F.F. TO CENTERLINE.
- FIRE EXTINGUISHER, BRACKET MOUNTED INSIDE BASE CABINET.
- WALL MOUNTED DRINKING FOUNTAIN, REFER TO PLUMBING.
- PROVIDE 12" HIGH WALL BLOCKING ON ENTIRE LENGTH OF WALL (FOR FUTURE ARTWORK), TOP OF BLOCKING TO BE 7'-0" A.F.F.
- WALL MOUNTED, INTEGRALLY LIT MIRROR, REFER TO ELECT.
- L-SHAPED ARCHITECTURAL TRIM INTEGRATED INTO WALL AND COVERED IN WALL FINISH MATERIAL, REFER TO GYPSUM BOARD ASSEMBLIES SPEC
- PROVIDE CUT-OUT IN COUNTER FOR BEER TAP. COORD. SIZE AND LOCATION WITH EQUIPMENT, REFER TO FOOD SERVICE DRAWINGS
- 18" WIDE PLASTIC LAMINATE SHELF WITH COAT BAR, TOP OF SHELF TO BE 70" A.F.F.
- 18" WIDE PLASTIC LAMINATE SHELF, TOP OF SHELF TO BE 70" A.F.F.
- 18" WIDE PLASTIC LAMINATE SHELF WITH COAT BAR, TOP OF SHELF TO BE 44" A.F.F.

- WALL-MOUNTED MONITOR, REFER TO TECH.
- DASHED LINE INDICATED COLD FORMED METAL FRAMED WALL FOR SUPPORT OF ATTIC FLOOR SYSTEM ABOVE.
- DASHED LINE INDICATES COLD-FORMED METAL FRAMED WALL FOR SUPPORT OF LADDER.

KEY PLAN

AREA A



REVISIONS

NO.	DATE	DESCRIPTION
1	10/27/2026	A2 ADDENDUM NO. 2

10/12/2026	BIDS & PERMIT
09/21/2026	CD PEER REVIEW
09/09/2026	CD TEAM REVIEW
08/10/2026	CD 50% PROGRESS
08/22/2026	DD OWNER REVIEW
06/15/2026	DD PEER REVIEW
06/08/2026	DD 90 % PROGRESS
05/18/2026	DD 90 % PROGRESS
02/23/2026	SD OWNER REVIEW
02/13/2026	SD PEER REVIEW
02/09/2026	SD PROGRESS REVIEW

Drawn By IOLKHOVESKA
Designer IELHENNAWY
Reviewer WLAPSON
Manager CKRETOVIC

Hard copy is intended to be 24"x36" when plotted. Scale(s) indicated and graphic quality may not be accurate for any other size.

PROJECT NO.
2500281

SHEET NO.


A101

©Copyright 2026
All Rights Reserved

Van Buren Charter Township

Van Buren Township, MI


The Lakeside Park

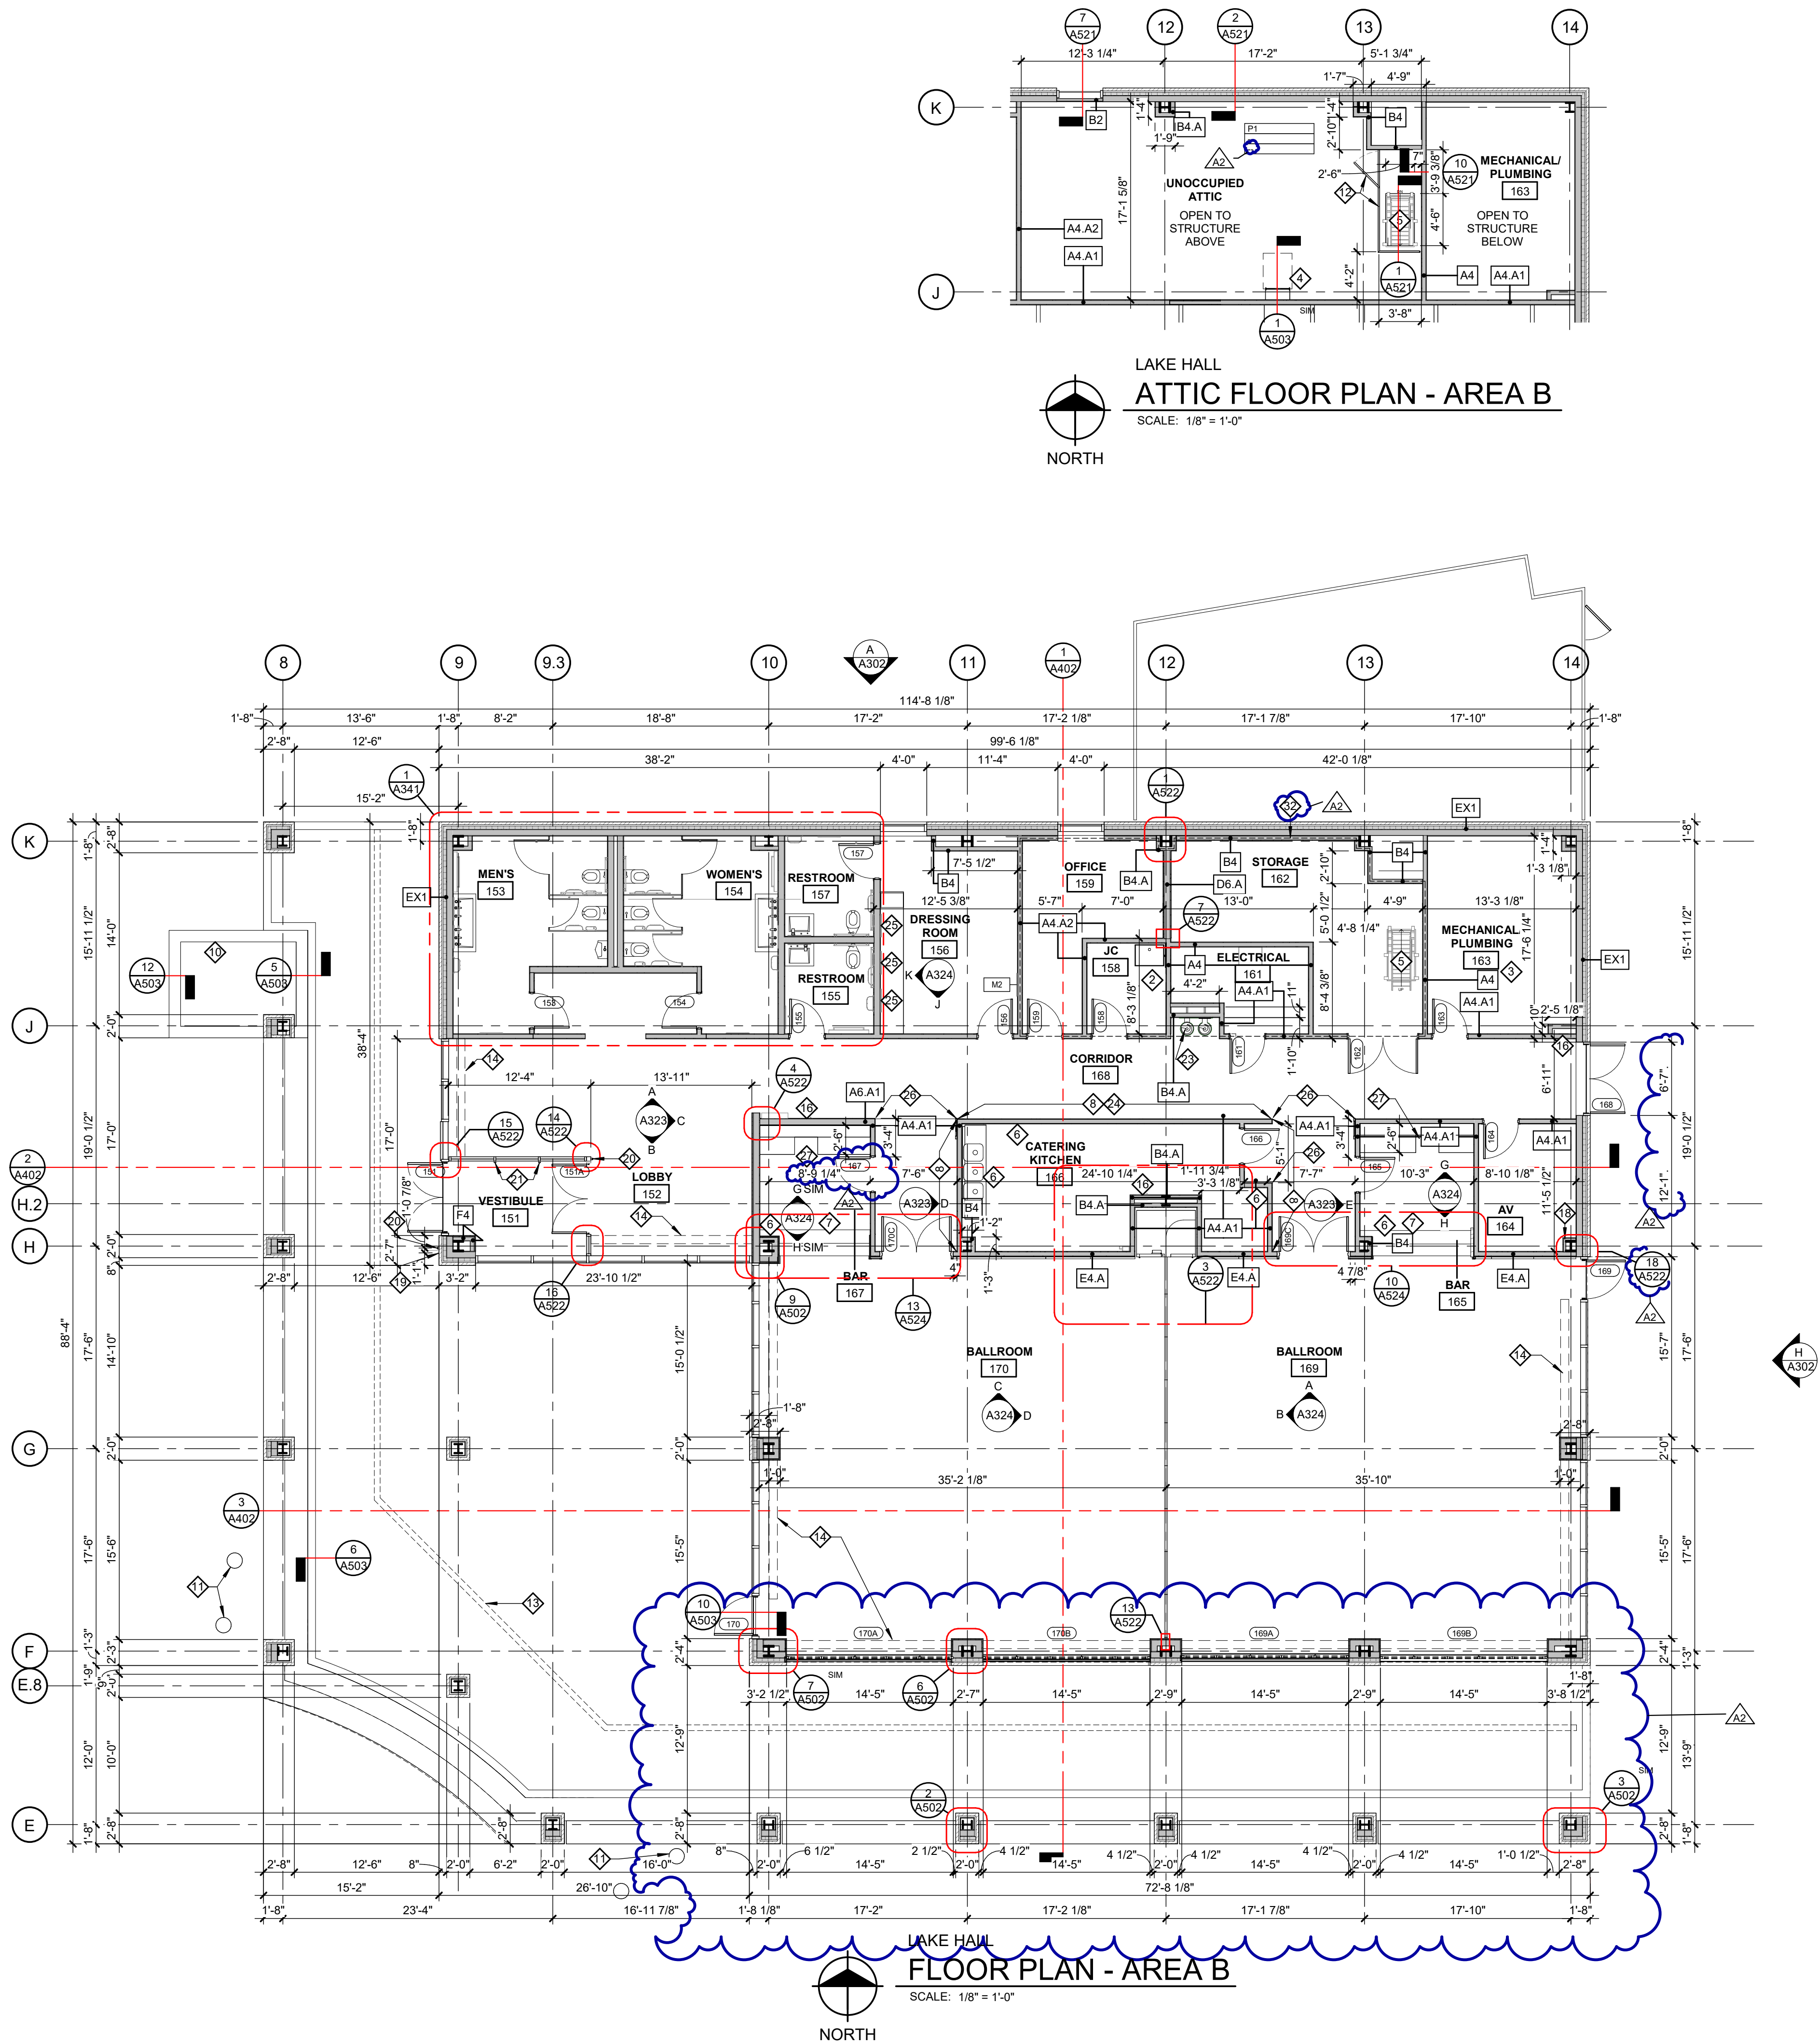

KEY NOTES

- CUSTOM VENTED SEE-THROUGH GAS FIREPLACE, REFER TO ELECT., MECH AND SPECS.; APPROX 5'W X 3'H
- SERVICE SINK REFER TO PLUMBING.
- OPEN TO STRUCTURE ABOVE.
- ROOF ACCESS LADDER AND HATCH DOOR ABOVE.
- ATTIC ACCESS HATCH WITH FOLD DOWN LADDER WITH FLAT LOWER / INTERIOR COVER
- KITCHEN SINK. REFER TO FOOD SERVICE AND PLUMBING.
- SOLID SURFACE BAR COUNTER (HIGH AND LOW) WITH BAR EQUIPMENT. REFER TO FOOD SERVICE DRAWINGS FOR BAR EQUIPMENT INFORMATION AND DETAILS.
- PROVIDE LEVEL 5 GYPSUM BOARD WALL FINISH ON ENTIRE LENGTH OF WALL.
- ROOF ACCESS LADDER AND HATCH DOOR ABOVE.
- ARCHITECTURAL PLANTER BOX REFER CIVIL AND STRUCTURAL FOR DETAILS
- SKYRING COLUMNS SEE SHEET A173 FOR DIMENSIONS
- 42-INCH HIGH PAINTED (SAFETY YELLOW) GUARDRAIL, TYPE HDRL-4, WITH 36" WIDE (CLEAR MIN.) SWING GATE.
- LINEAR DRAINS BELOW PEDESTAL PAVER SYSTEM, REFER TO CIVIL FOR DRAINS
- IN FLOOR MECHANICAL TRENCH, REFER TO MECHANICAL.
- TIERED SEATING, STAIRS, AND HANDRAIL; REFER TO CIVIL DRAWINGS FOR DETAIL
- FULLY-RECESSED FIRE EXTINGUISHER CABINET W/ EXTINGUISHER. PAINT TO MATCH ADJACENT WALL FINISH.
- MECHANICAL SCREEN WALLS AND GATE. MATERIAL AND CONSTRUCTION TO BE DETERMINED. REFER TO ELEVATIONS FOR HEIGHT
- 5/8" GYPSUM BOARD ON 2-1/2" METAL STUD FRAMING; PROVIDE TIGHT-FITTING ENCLOSURE AROUND COLUMN.
- CARD READER: 42" A.F.F. TO CENTERLINE.
- ACTUATOR BUTTON OPERATOR: 42" A.F.F. TO CENTERLINE.
- ROUGH-IN FOR FUTURE ACTUATOR BUTTON 42" A.F.F. TO CENTERLINE.
- FIRE EXTINGUISHER, BRACKET MOUNTED INSIDE BASE CABINET.
- WALL MOUNTED DRINKING FOUNTAIN, REFER TO PLUMBING.
- PROVIDE 12" HIGH WALL BLOCKING ON ENTIRE LENGTH OF WALL (FOR FUTURE ARTWORK), TOP OF BLOCKING TO BE 7'-0" A.F.F.
- WALL MOUNTED, INTEGRALLY LIT MIRROR, REFER TO ELECT.
- L-SHAPED ARCHITECTURAL TRIM INTEGRATED INTO WALL, AND COVERED IN WALL FINISH MATERIAL. REFER TO GYPSUM BOARD ASSEMBLIES SPEC
- PROVIDE CUT-OUT IN COUNTER FOR BEER TAP. COORD. SIZE AND LOCATION WITH EQUIPMENT, REFER TO FOOD SERVICE DRAWINGS
- 18" WIDE PLASTIC LAMINATE SHELF WITH COAT BAR, TOP OF SHELF TO BE 70" A.F.F.
- 18" WIDE PLASTIC LAMINATE SHELF, TOP OF SHELF TO BE 70" A.F.F.
- 18" WIDE PLASTIC LAMINATE SHELF WITH COAT BAR, TOP OF SHELF TO BE 44" A.F.F.
- WALL-MOUNTED MONITOR, REFER TO TECH.
- DASHED LINE INDICATED COLD FORMED METAL FRAMED WALL FOR SUPPORT OF ATTIC FLOOR SYSTEM ABOVE.
- DASHED LINE INDICATES COLD-FORMED METAL FRAMED WALL FOR SUPPORT OF LADDER.

KEY PLAN

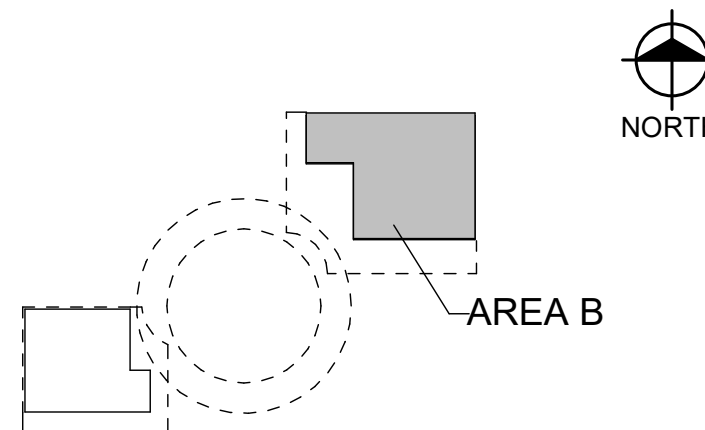

Van Buren Charter Township

Van Buren Township, MI

The Lakeside Park

REVISIONS		
10/27/2026	A2	ADDENDUM NO. 2


10/12/2026	BIDS & PERMIT
09/21/2026	CD PEER REVIEW
09/09/2026	CD TEAM REVIEW
08/10/2026	CD 50% PROGRESS
08/22/2026	DD OWNER REVIEW
06/15/2026	DD PEER REVIEW
06/08/2026	DD 90% PROGRESS
05/18/2026	DD 90% PROGRESS
02/23/2026	SD OWNER REVIEW
02/13/2026	SD PEER REVIEW
02/09/2026	SD PROGRESS REVIEW

Drawn By	IOLKHOVESKA
Designer	IELHENNAWY
Reviewer	WLAPSON
Manager	CKRETOVIC

Hard copy is intended to be 24"x36" when plotted. Scale(s) indicated and graphic quality may not be accurate for any other size.

PROJECT NO.	2500281
SHEET NO.	


A102

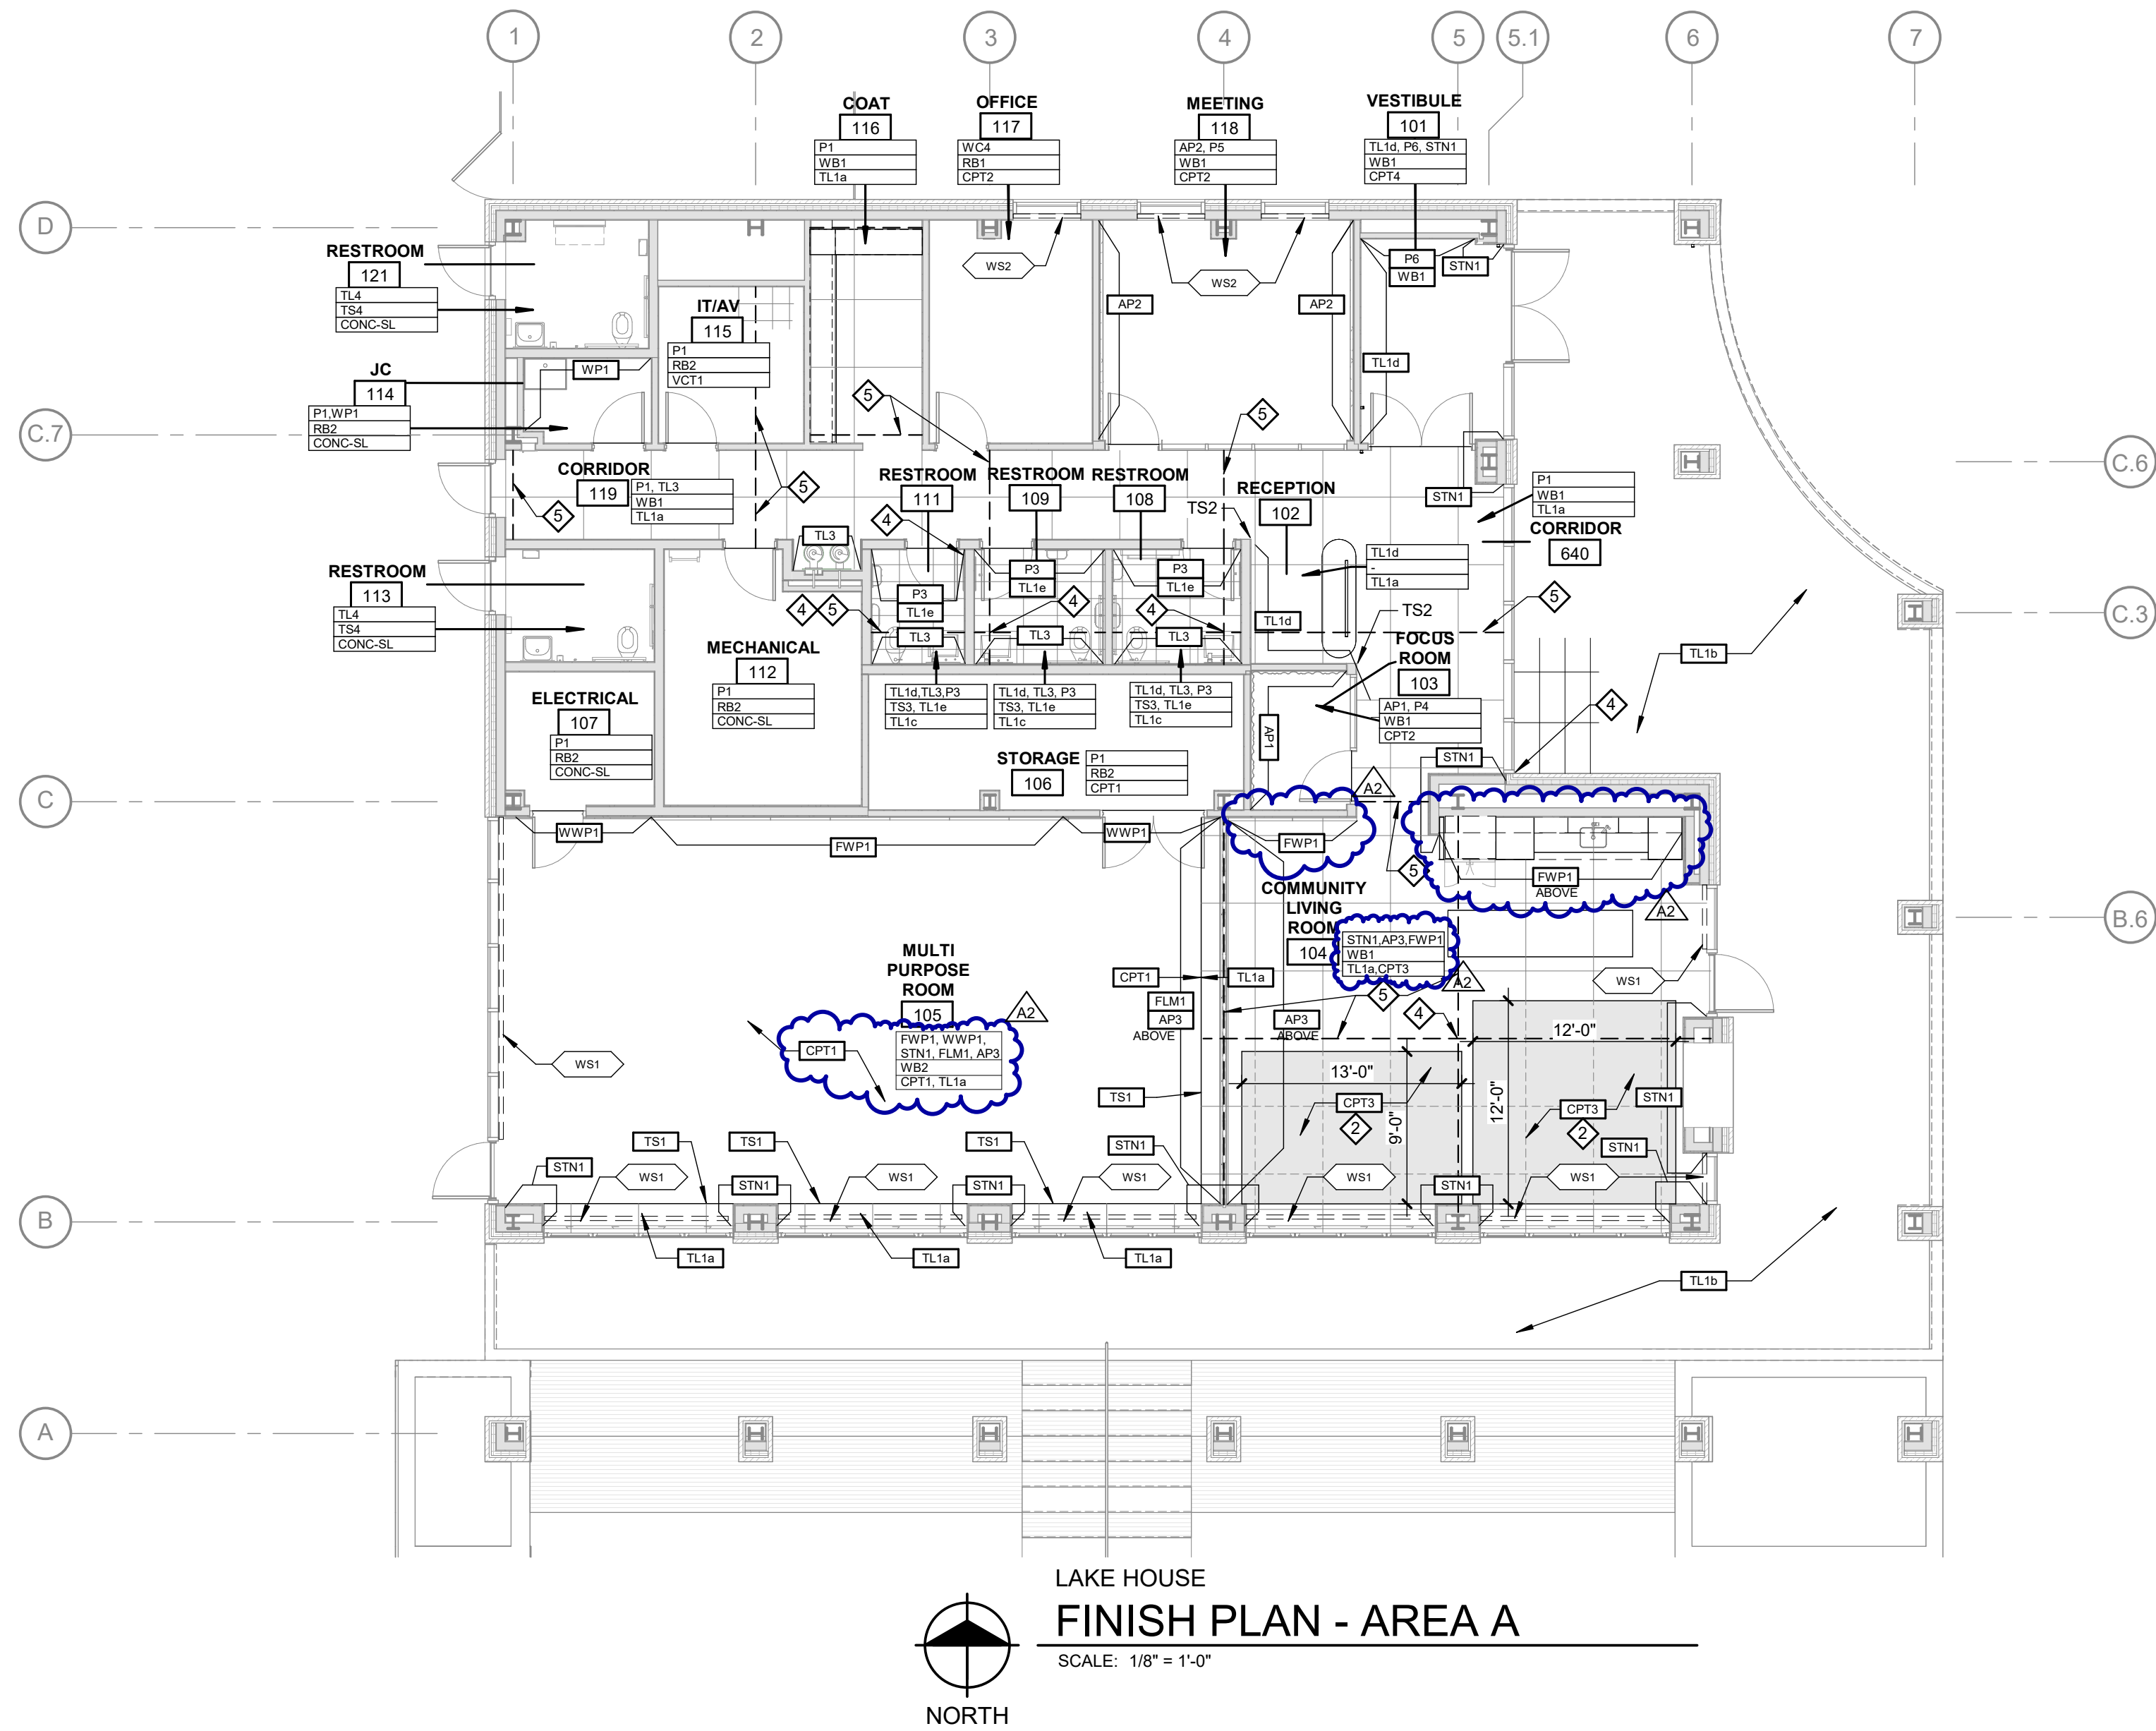

KEY NOTES

- 1 INTEGRATED RECESSES WITHIN STONE WITH ACRYLIC PANEL ACCENTS AND LIGHTING
- 2 TILE CONTINUES BELOW CPT RUG
- 3 CUSTOM GRAPHIC VINYL PROVIDED AND INSTALLED BY IMAGE360
- 4 TILE PATTERN START
- 5 TILE SOFT JOINT, LOCATED OVER CONCRETE SLAB CONTROL JOINT
- 6 CUT TILES TO ACCOMMODATE OVERALL PATTERN AND CONTROL JOINT LOCATION
- 7 ADDED TILE SOFT JOINT FOR DIRECT SUN LOCATION
- 8 WALL FINISH TO CONTINUE OVER WALL EMBEDDED L-SHAPED ARCHITECTURAL CORNER TRIM, REFER TO FLOOR PLAN

KEY PLAN

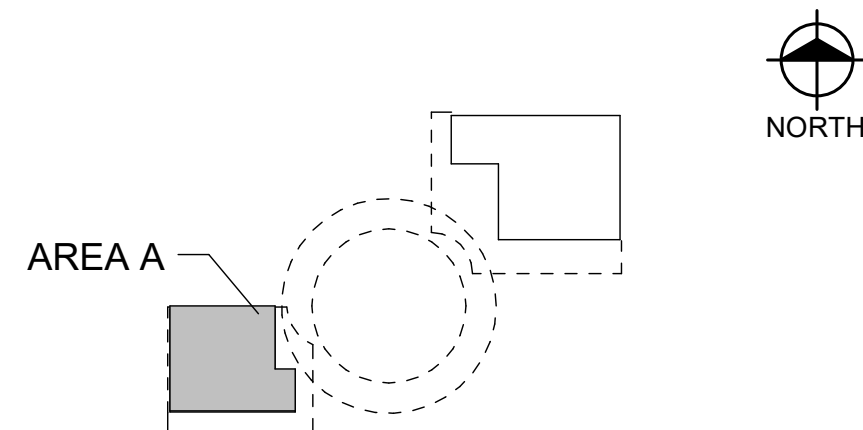

Van Buren Charter Township

Van Buren Township, MI

The Lakeside Park

REVISIONS		
10/27/2026	A2	ADDENDUM NO. 2

10/12/2026	BIDS & PERMIT
09/21/2026	CD PEER REVIEW
09/09/2026	CD TEAM REVIEW
08/10/2026	CD 50% PROGRESS
08/22/2026	DD OWNER REVIEW
06/15/2026	DD PEER REVIEW
06/08/2026	DD 90 % PROGRESS
05/18/2026	DD 90 % PROGRESS
02/23/2026	SD OWNER REVIEW
02/13/2026	SD PEER REVIEW
02/09/2026	SD PROGRESS REVIEW

Drawn By	IOLKHOVESKA
Designer	KBRAUN
Reviewer	WLRAPSON
Manager	CKRETOVIC

Hard copy is intended to be 24"x36" when plotted. Scale(s) indicated and graphic quality may not be accurate for any other size.


PROJECT NO.
2500281

SHEET NO.

A131

©Copyright 2026
All Rights Reserved

PLOT INFO: 10/27/2026 2:55:31 PM Autodesk Docs://2500281 - Van Buren Twp Lake House/2026_A_2500281.rvt

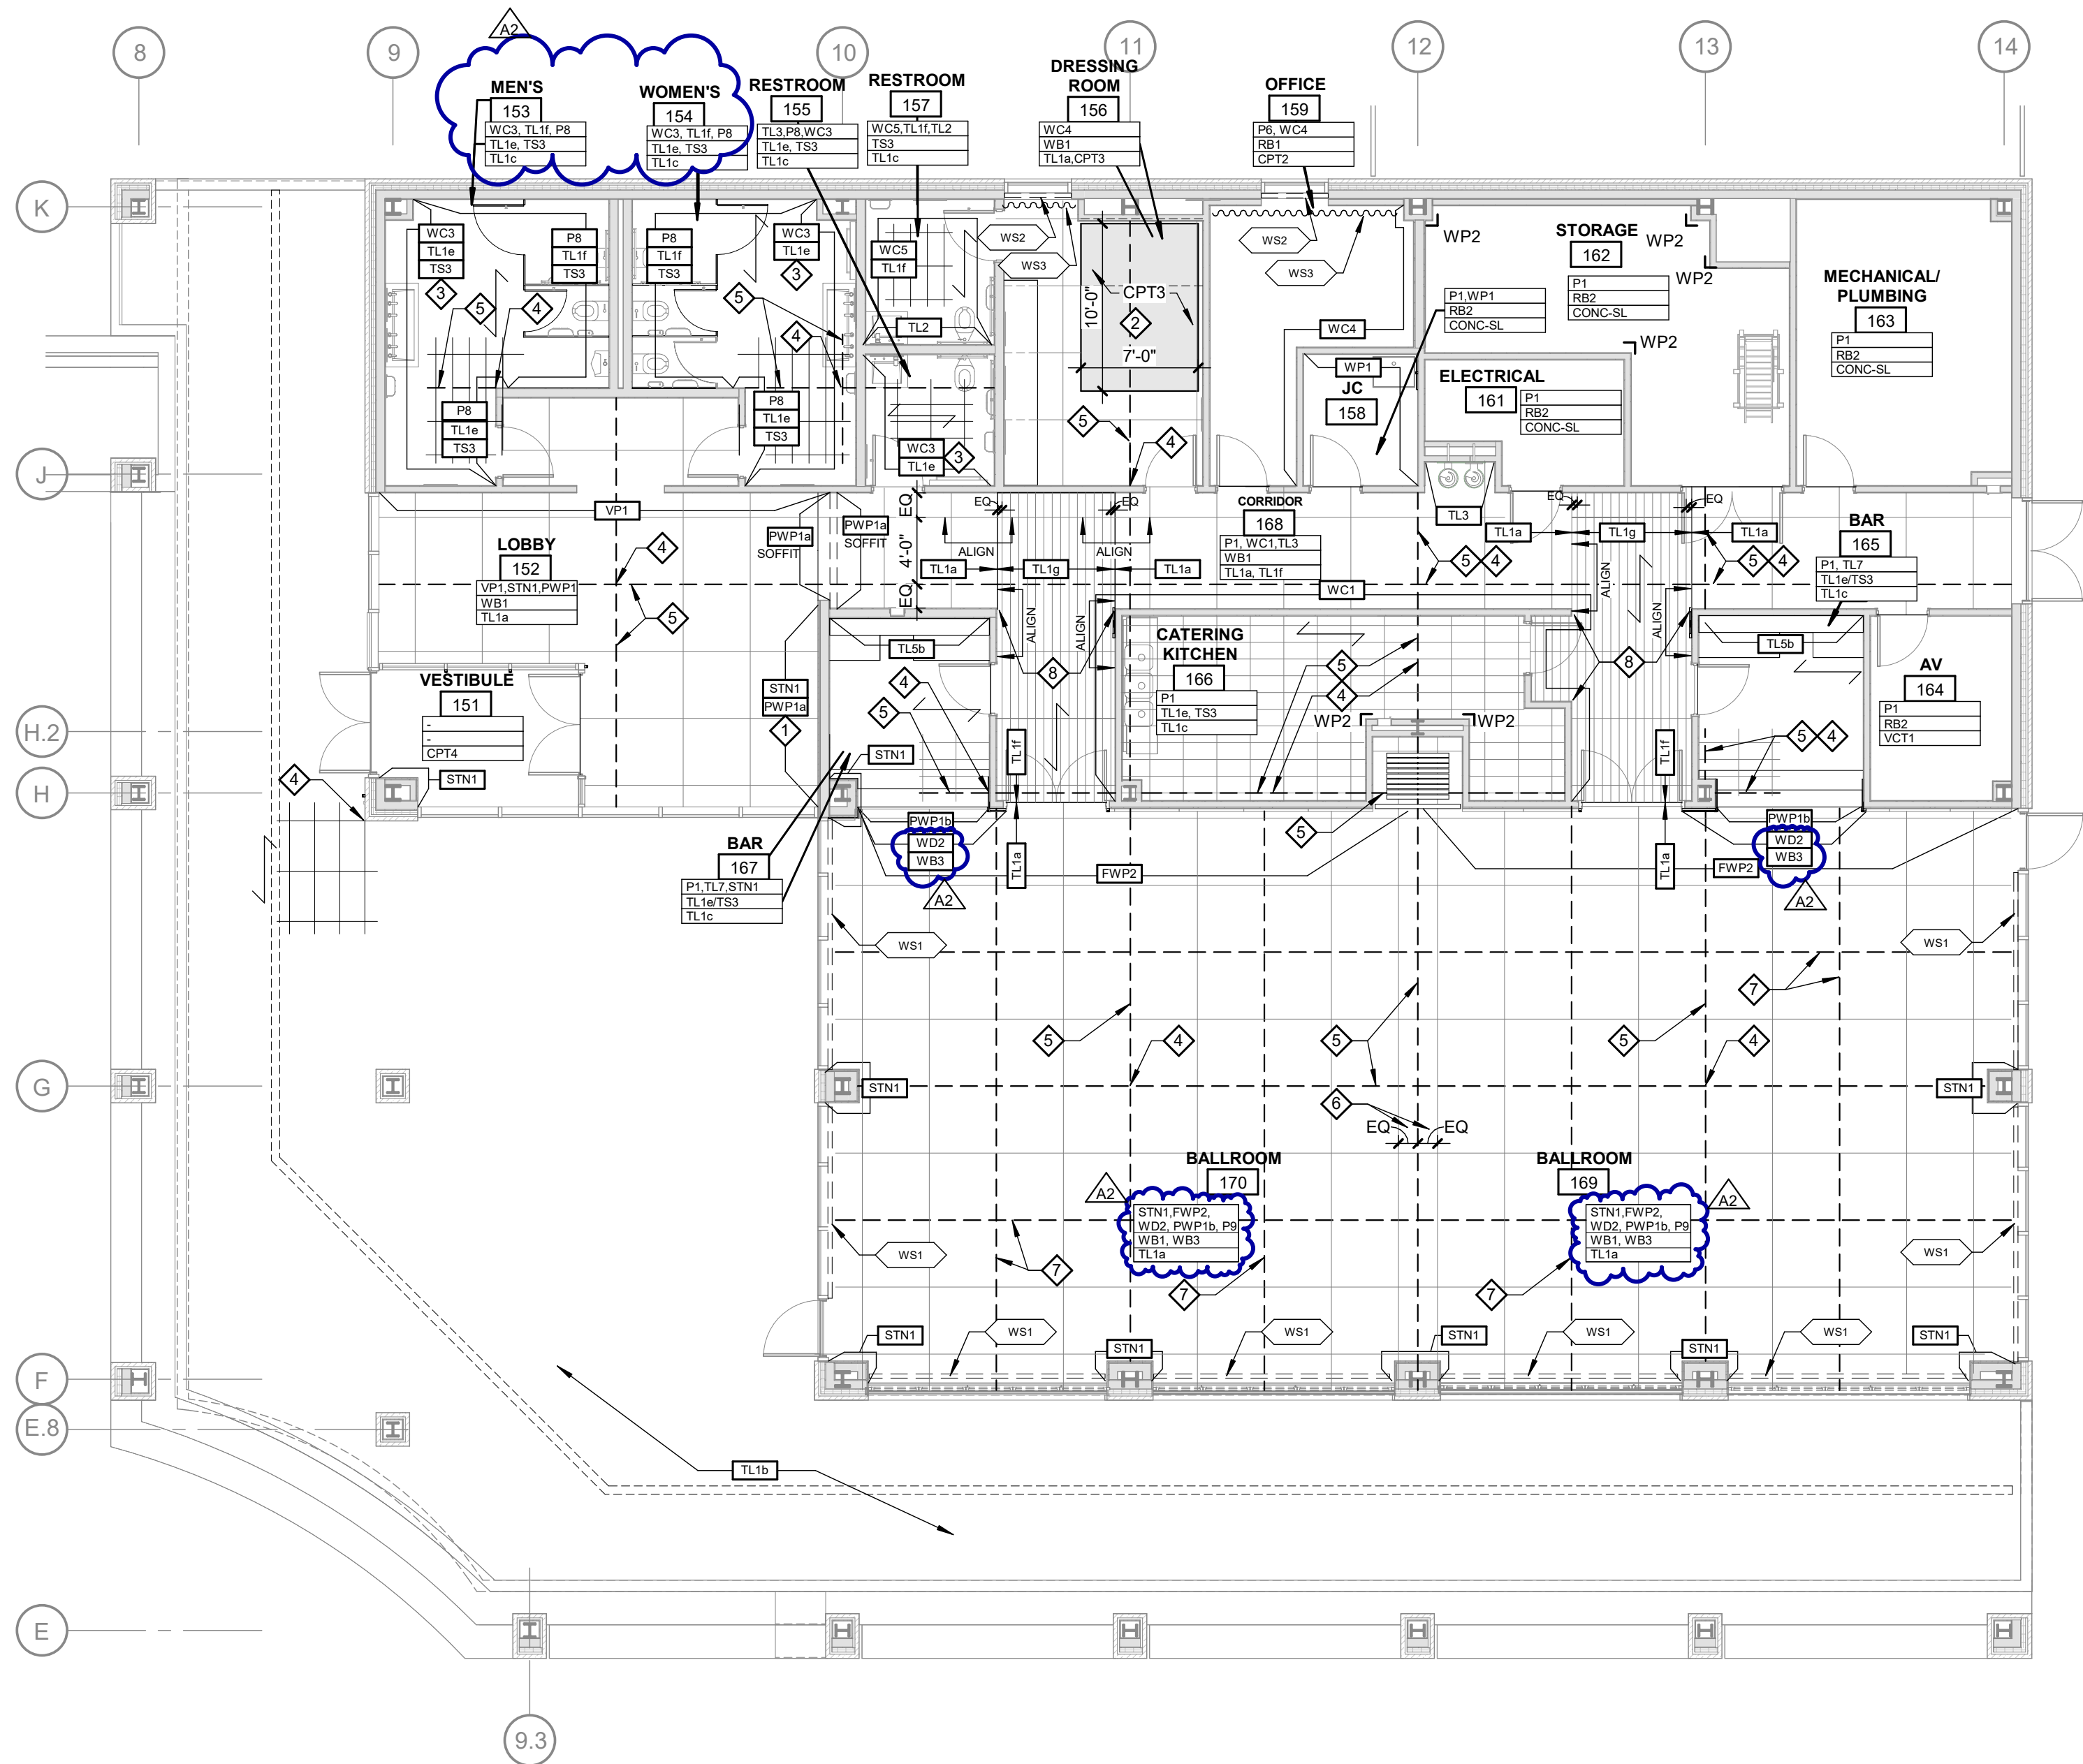


LAKE HALL
FINISH PLAN - AREA B
SCALE: 1/8" = 1'-0"

KEY NOTES

- 1 INTEGRATED RECESSES WITHIN STONE WITH ACRYLIC PANEL ACCENTS AND LIGHTING
- 2 TILE CONTINUES BELOW CPT RUG
- 3 CUSTOM GRAPHIC VINYL PROVIDED AND INSTALLED BY IMAGE360
- 4 TILE PATTERN START
- 5 TILE SOFT JOINT, LOCATED OVER CONCRETE SLAB CONTROL JOINT
- 6 CUT TILES TO ACCOMMODATE OVERALL PATTERN AND CONTROL JOINT LOCATION
- 7 ADDED TILE SOFT JOINT FOR DIRECT SUN LOCATION
- 8 WALL FINISH TO CONTINUE OVER WALL EMBEDDED L-SHAPED ARCHITECTURAL CORNER TRIM, REFER TO FLOOR PLAN

A2

KEY PLAN

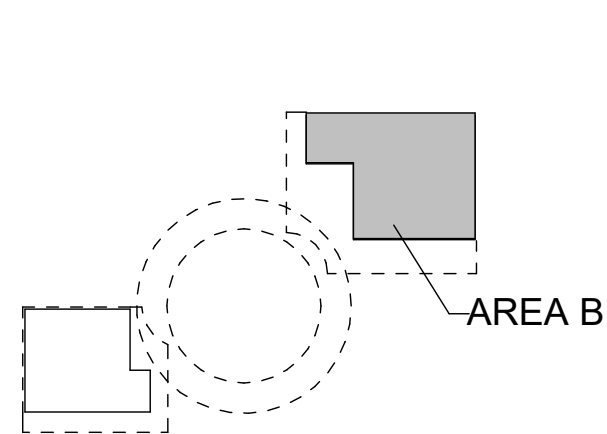

Van Buren Charter Township

Van Buren Township, MI

The Lakeside Park

REVISIONS		
10/27/2026	A2	ADDENDUM NO. 2

10/12/2026	BIDS & PERMIT
09/21/2026	CD PEER REVIEW
09/09/2026	CD TEAM REVIEW
08/10/2026	CD 50% PROGRESS
08/22/2026	DD OWNER REVIEW
06/15/2026	DD PEER REVIEW
06/08/2026	DD 90 % PROGRESS
05/18/2026	DD 50 % PROGRESS
02/23/2026	SD OWNER REVIEW
02/13/2026	SD PEER REVIEW
02/09/2026	SD PROGRESS REVIEW

Drawn By	IOLKHOVESKA
Designer	KBRAUN
Reviewer	WLRAPSON
Manager	CKRETOVIC

Hard copy is intended to be 24"x36" when plotted. Scale(s) indicated and graphic quality may not be accurate for any other size.

PROJECT NO.
2500281

SHEET NO.


A132

©Copyright 2026
All Rights Reserved

PLOT INFO: 10/27/2026 2:55:36 PM Autodesk Docs://2500281 - Van Buren Twp Lake House/2026_A_2500281.rvt

GENERAL FURNITURE NOTES

- 1. FURNITURE SHOWN FOR REFERENCE ONLY
- 2. FINAL FURNITURE SPECIFICATION BY FURNITURE DEALER IN COORDINATION WITH DESIGNER.
- 3. SITE DEPICTED FOR EXTERIOR FURNITURE PLACEMENT ONLY. REFER TO CIVILLANDSCAPE DRAWINGS.

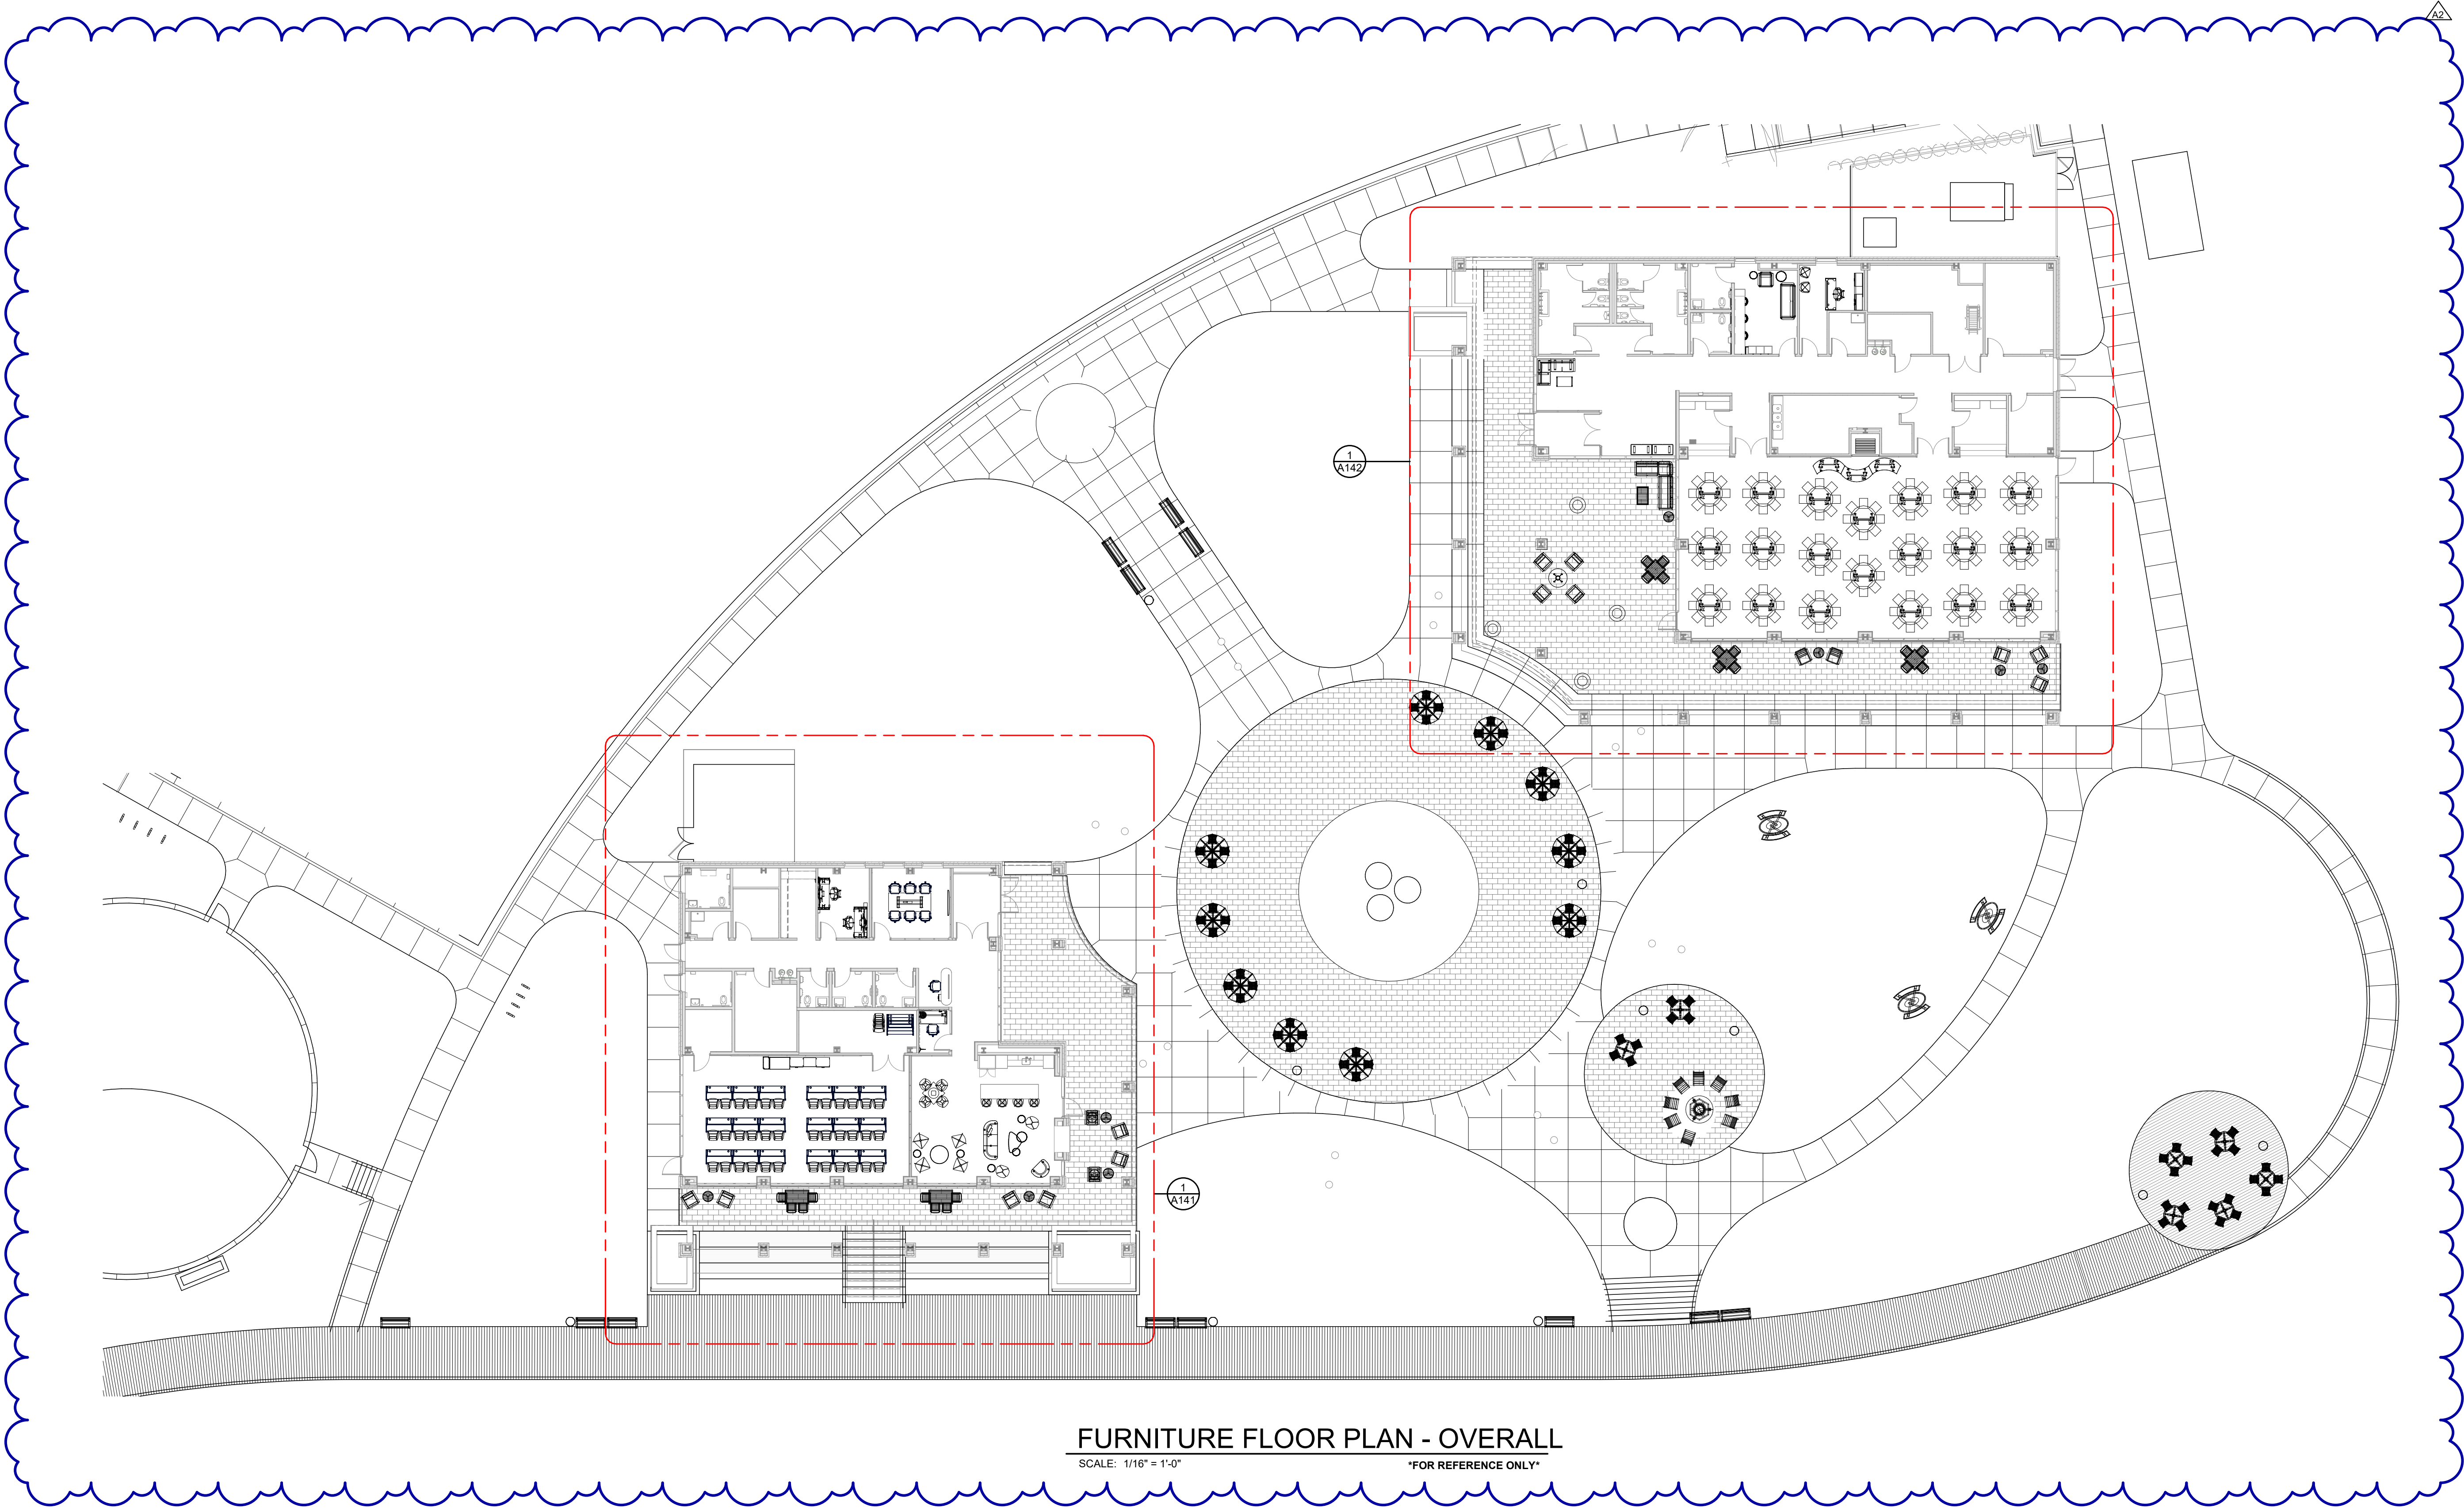

FURNITURE FLOOR PLAN - OVERALL

SCALE: 1/16" = 1'-0"

FOR REFERENCE ONLY

Van Buren Charter Township

Van Buren Township, MI

The Lakeside Park

REVISIONS		
10/27/2026	A2	ADDENDUM NO. 2

10/12/2026	BIDS & PERMIT
09/21/2026	CD PEER REVIEW
09/09/2026	CD TEAM REVIEW
08/10/2026	CD 50% PROGRESS
08/22/2026	DD OWNER REVIEW
06/15/2026	DD PEER REVIEW
06/08/2026	DD 90 % PROGRESS
05/18/2026	DD 50 % PROGRESS
02/23/2026	SD OWNER REVIEW
02/13/2026	SD PEER REVIEW
02/09/2026	SD PROGRESS REVIEW

Drawn By	IOLKHOVESKA
Designer	KBRAUN
Reviewer	WLRAPSON
Manager	CKRETOVIC


Hard copy is intended to be 24"x36" when plotted. Scale(s) indicated and graphic quality may not be accurate for any other size.

PROJECT NO.
2500281

SHEET NO.

A140

©Copyright 2026
All Rights Reserved

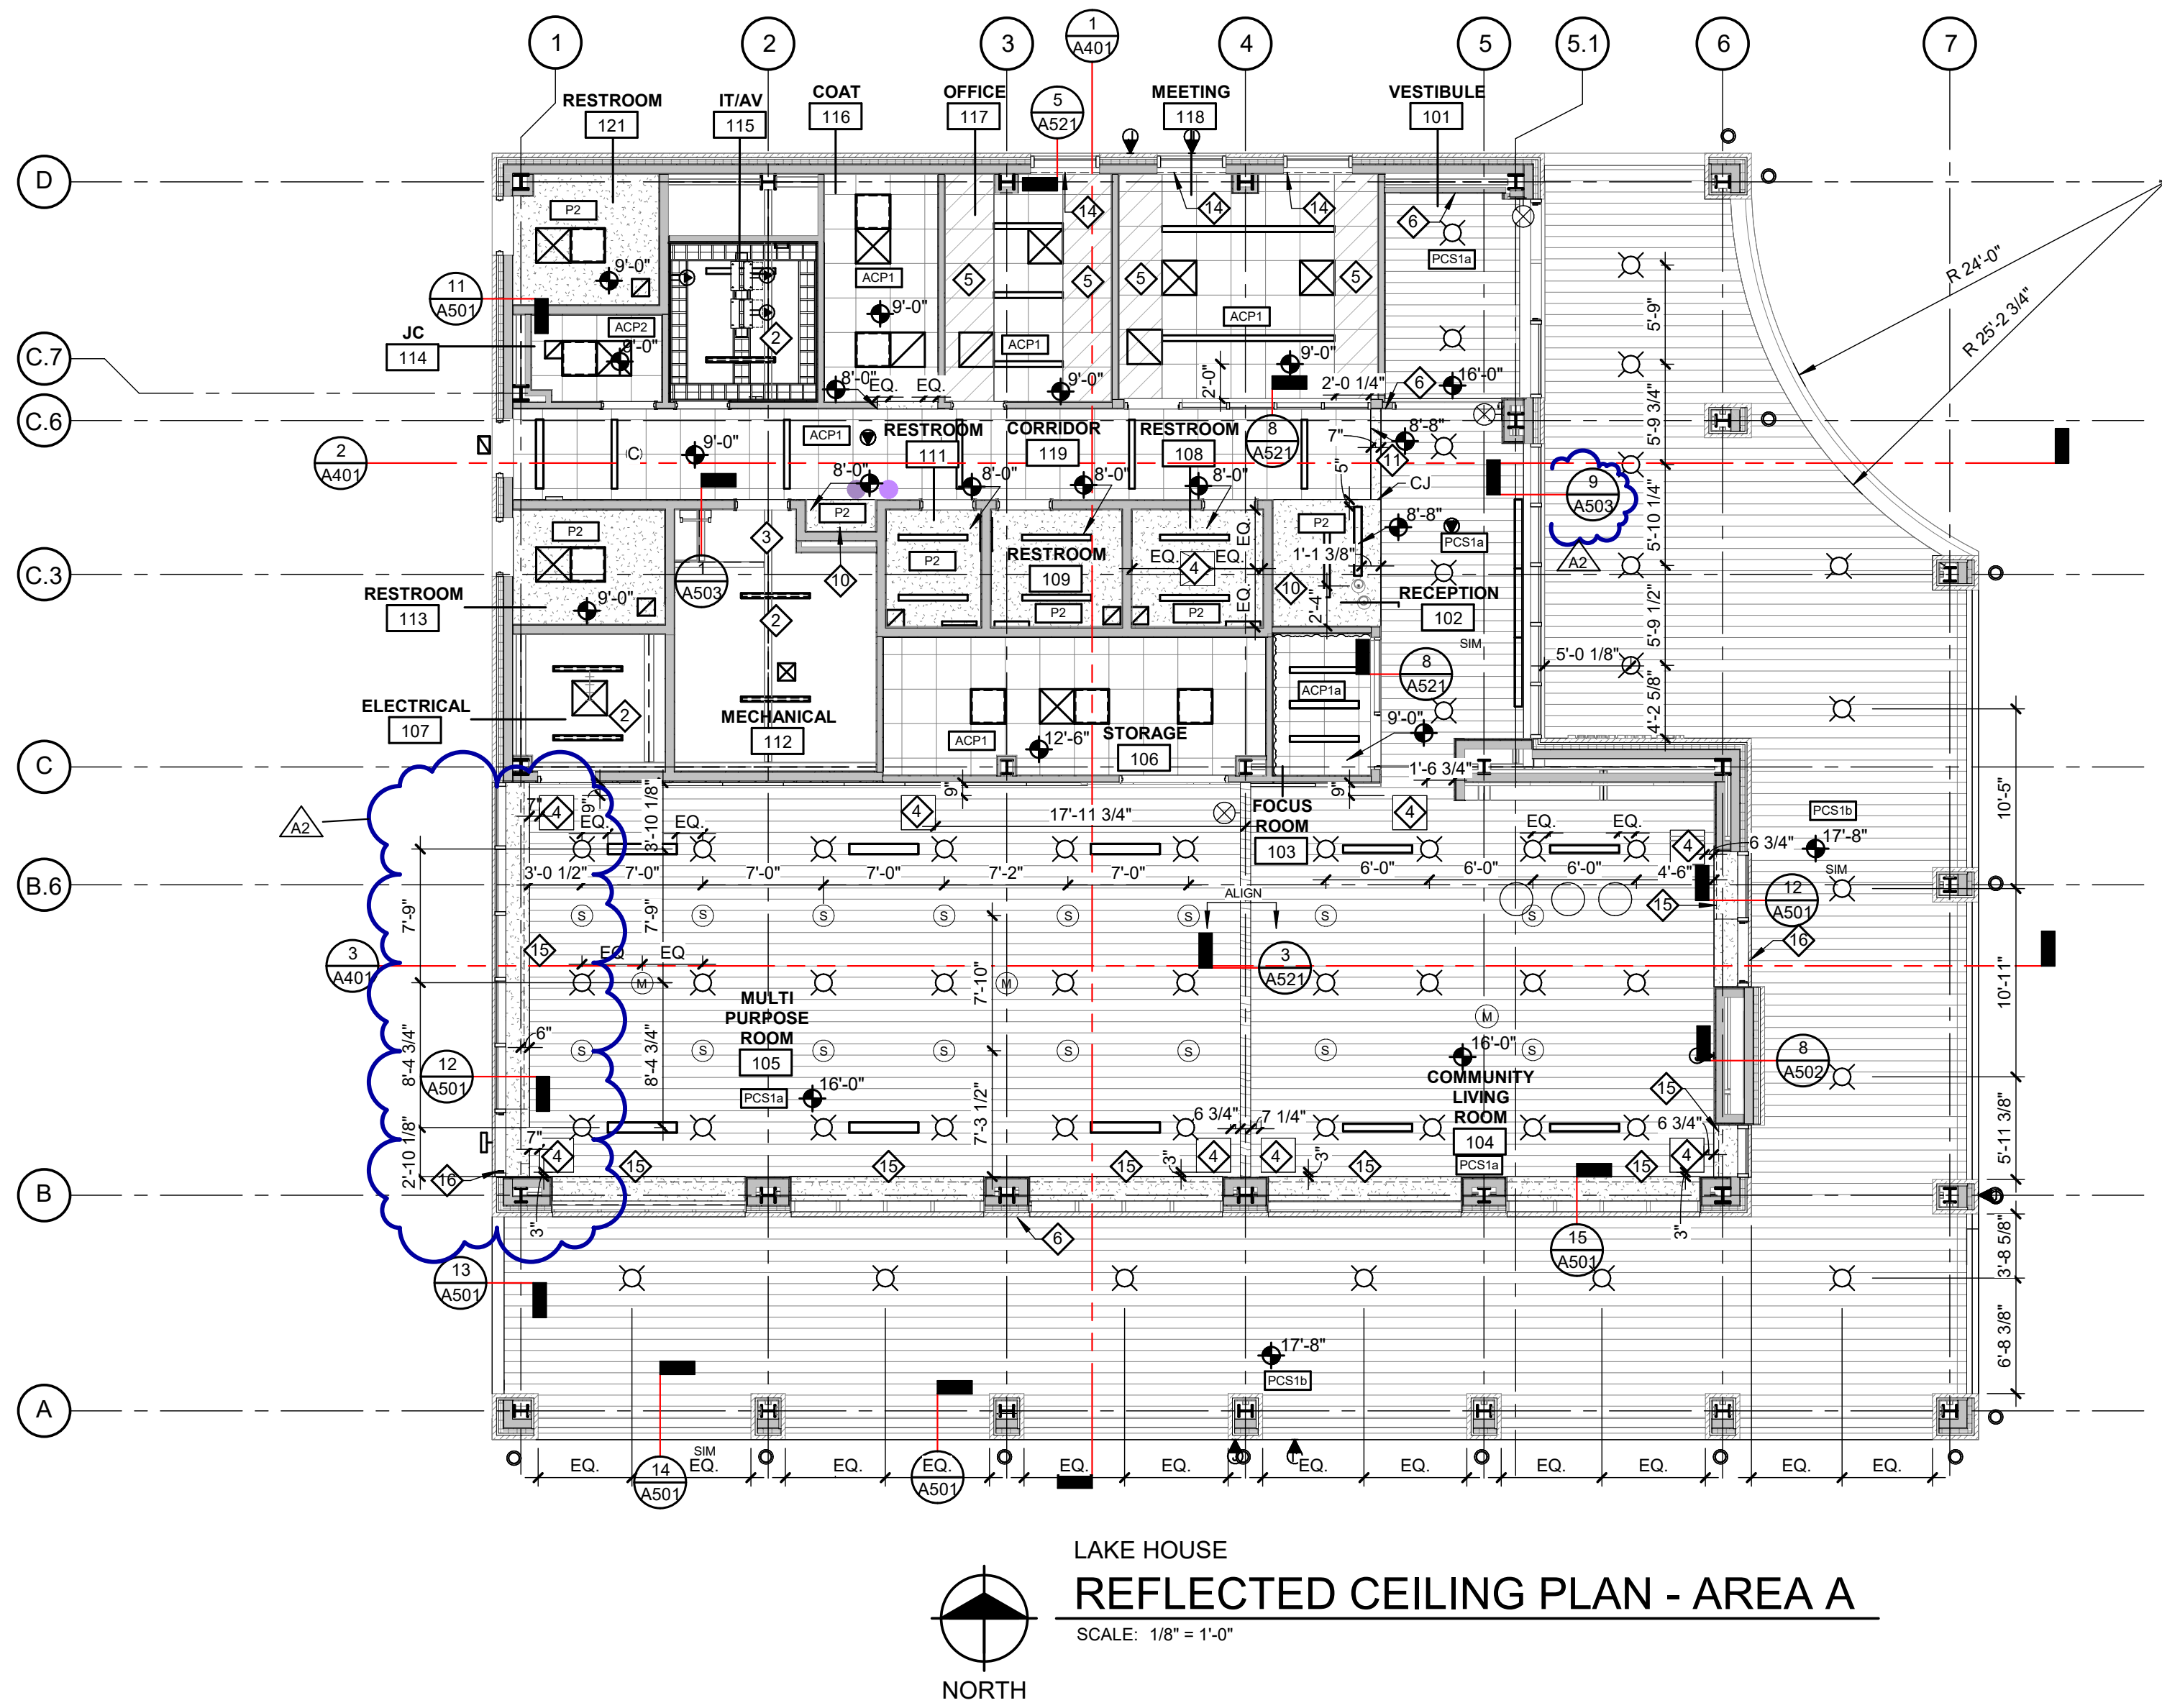

LAKE HOUSE
REFLECTED CEILING PLAN - AREA A
SCALE: 1/8" = 1'-0"

GENERAL REFLECTED CEILING PLAN NOTES


1. ALL CEILING ELEVATIONS ARE ABOVE FINISH FLOOR
2. ALL CEILING GRIDS ARE TO BE CENTERED ON ROOM / AREA U.N.O
3. CENTER HVAC DIFFUSERS AND LIGHTING ON METAL CEILING PANELS.

WHERE LIGHT FIXTURES ARE TO BE MOUNTED IN LINEAR METAL CEILINGS, DIMENSION PROVIDED IN REFLECTED CEILING PLANS IS TO BE VERIFIED IN FIELD SO FIXTURE IS LOCATED CENTERED WITHIN AN INDIVIDUAL LINEAR METAL SLAT.

KEY NOTES

- 1 ACOUSTIC ROOM COMPONENTS - MOBILE, LIGHTART ACOUSTIC MOBILE; AIRCRAFT CABLE SUPPORTS WITH FOLDED SQUARE PET SOLA FELT IN COLORS DUNE & DRIFTWOOD
- 2 OPEN TO STRUCTURE ABOVE.
- 3 ROOF HATCH DOOR.
- 4 ACCESS DOOR, 2' X 2' UNLESS OTHERWISE NOTED.
- 5 DIAGONAL HATCH; CUT OVERSIZED TILES AS REQUIRED TO CENTER CEILING GRID IN ROOM.
- 6 START METAL PLANK CEILING LAYOUT FROM NORTH WALL; MAINTAIN CONSISTENT PLANK ALIGNMENT THROUGHOUT.
- 7 DECORATIVE CHANDELIER, REFER TO ELECTRICAL.
- 8 PROJECTOR, REFER TO TECHNOLOGY.
- 9 PROJECTION SCREEN, REFER TO TECHNOLOGY.
- 10 SOFFIT, REFER TO TYPICAL SOFFIT DETAIL 1/A201
- 11 BULKHEAD, REFER TO TYPICAL BULKHEAD DETAIL 2/A201
- 12 LINE OF CONT. LIGHT COVE AT SOFFIT 5/A524
- 13 LINE OF DRAPERY TRACK. TRACK TO EXTEND FULL WIDTH OF WALL. REFER TO SCHEDULES.
- 14 LINE OF SOFFIT MOUNTED ROLLER SHADE (DO NOT PUNCTURE OR MOUNT TO WINDOW FRAME), REFER TO SCHEDULES.
- 15 LINE OF SOFFIT MOUNTED DOUBLE ROLLER SHADE, REFER TO SCHEDULES.
- 16 EGRESS DOOR, BELOW. STOP ROLLER SHADE IN ALIGNMENT WITH OUTSIDE FACE OF DOOR JAMB AND DO NOT EXTEND ROLLER SHADE OVER DOOR.
- 17 ATTIC ACCESS HATCH WITH PULL-DOWN LADDER.

KEY PLAN

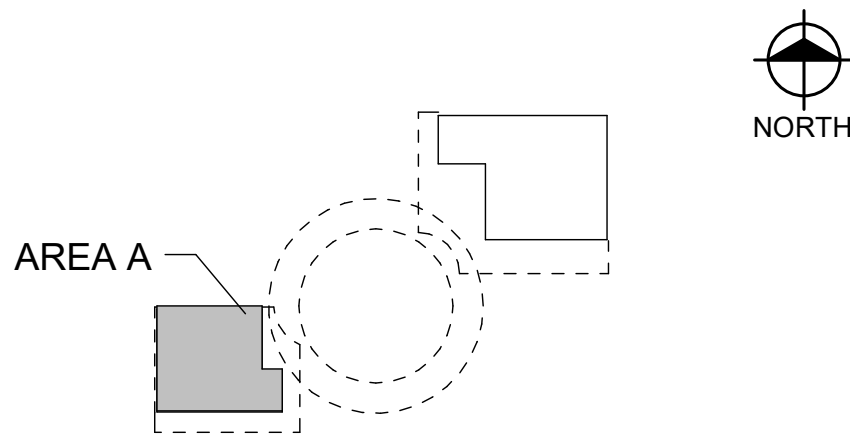

Van Buren Charter Township
Van Buren Township, MI
The Lakeside Park

REVISIONS		
10/27/2026	A2	ADDENDUM NO. 2


10/12/2026	BIDS & PERMIT
09/21/2026	CD PEER REVIEW
08/09/2026	CD TEAM REVIEW
08/10/2026	CD 50% PROGRESS
08/22/2026	DD OWNER REVIEW
06/15/2026	DD PEER REVIEW
06/08/2026	DD 90 % PROGRESS
05/18/2026	DD 90 % PROGRESS
02/23/2026	SD OWNER REVIEW
02/13/2026	SD PEER REVIEW
02/09/2026	SD PROGRESS REVIEW

Drawn By	IOLKHOVESKA
Designer	IELHENNAWY
Reviewer	WLAPSON
Manager	CKRETOVIC

Hard copy is intended to be 24"x36" when plotted. Scale(s) indicated and graphic quality may not be accurate for any other size.

PROJECT NO.
2500281
SHEET NO.


A151

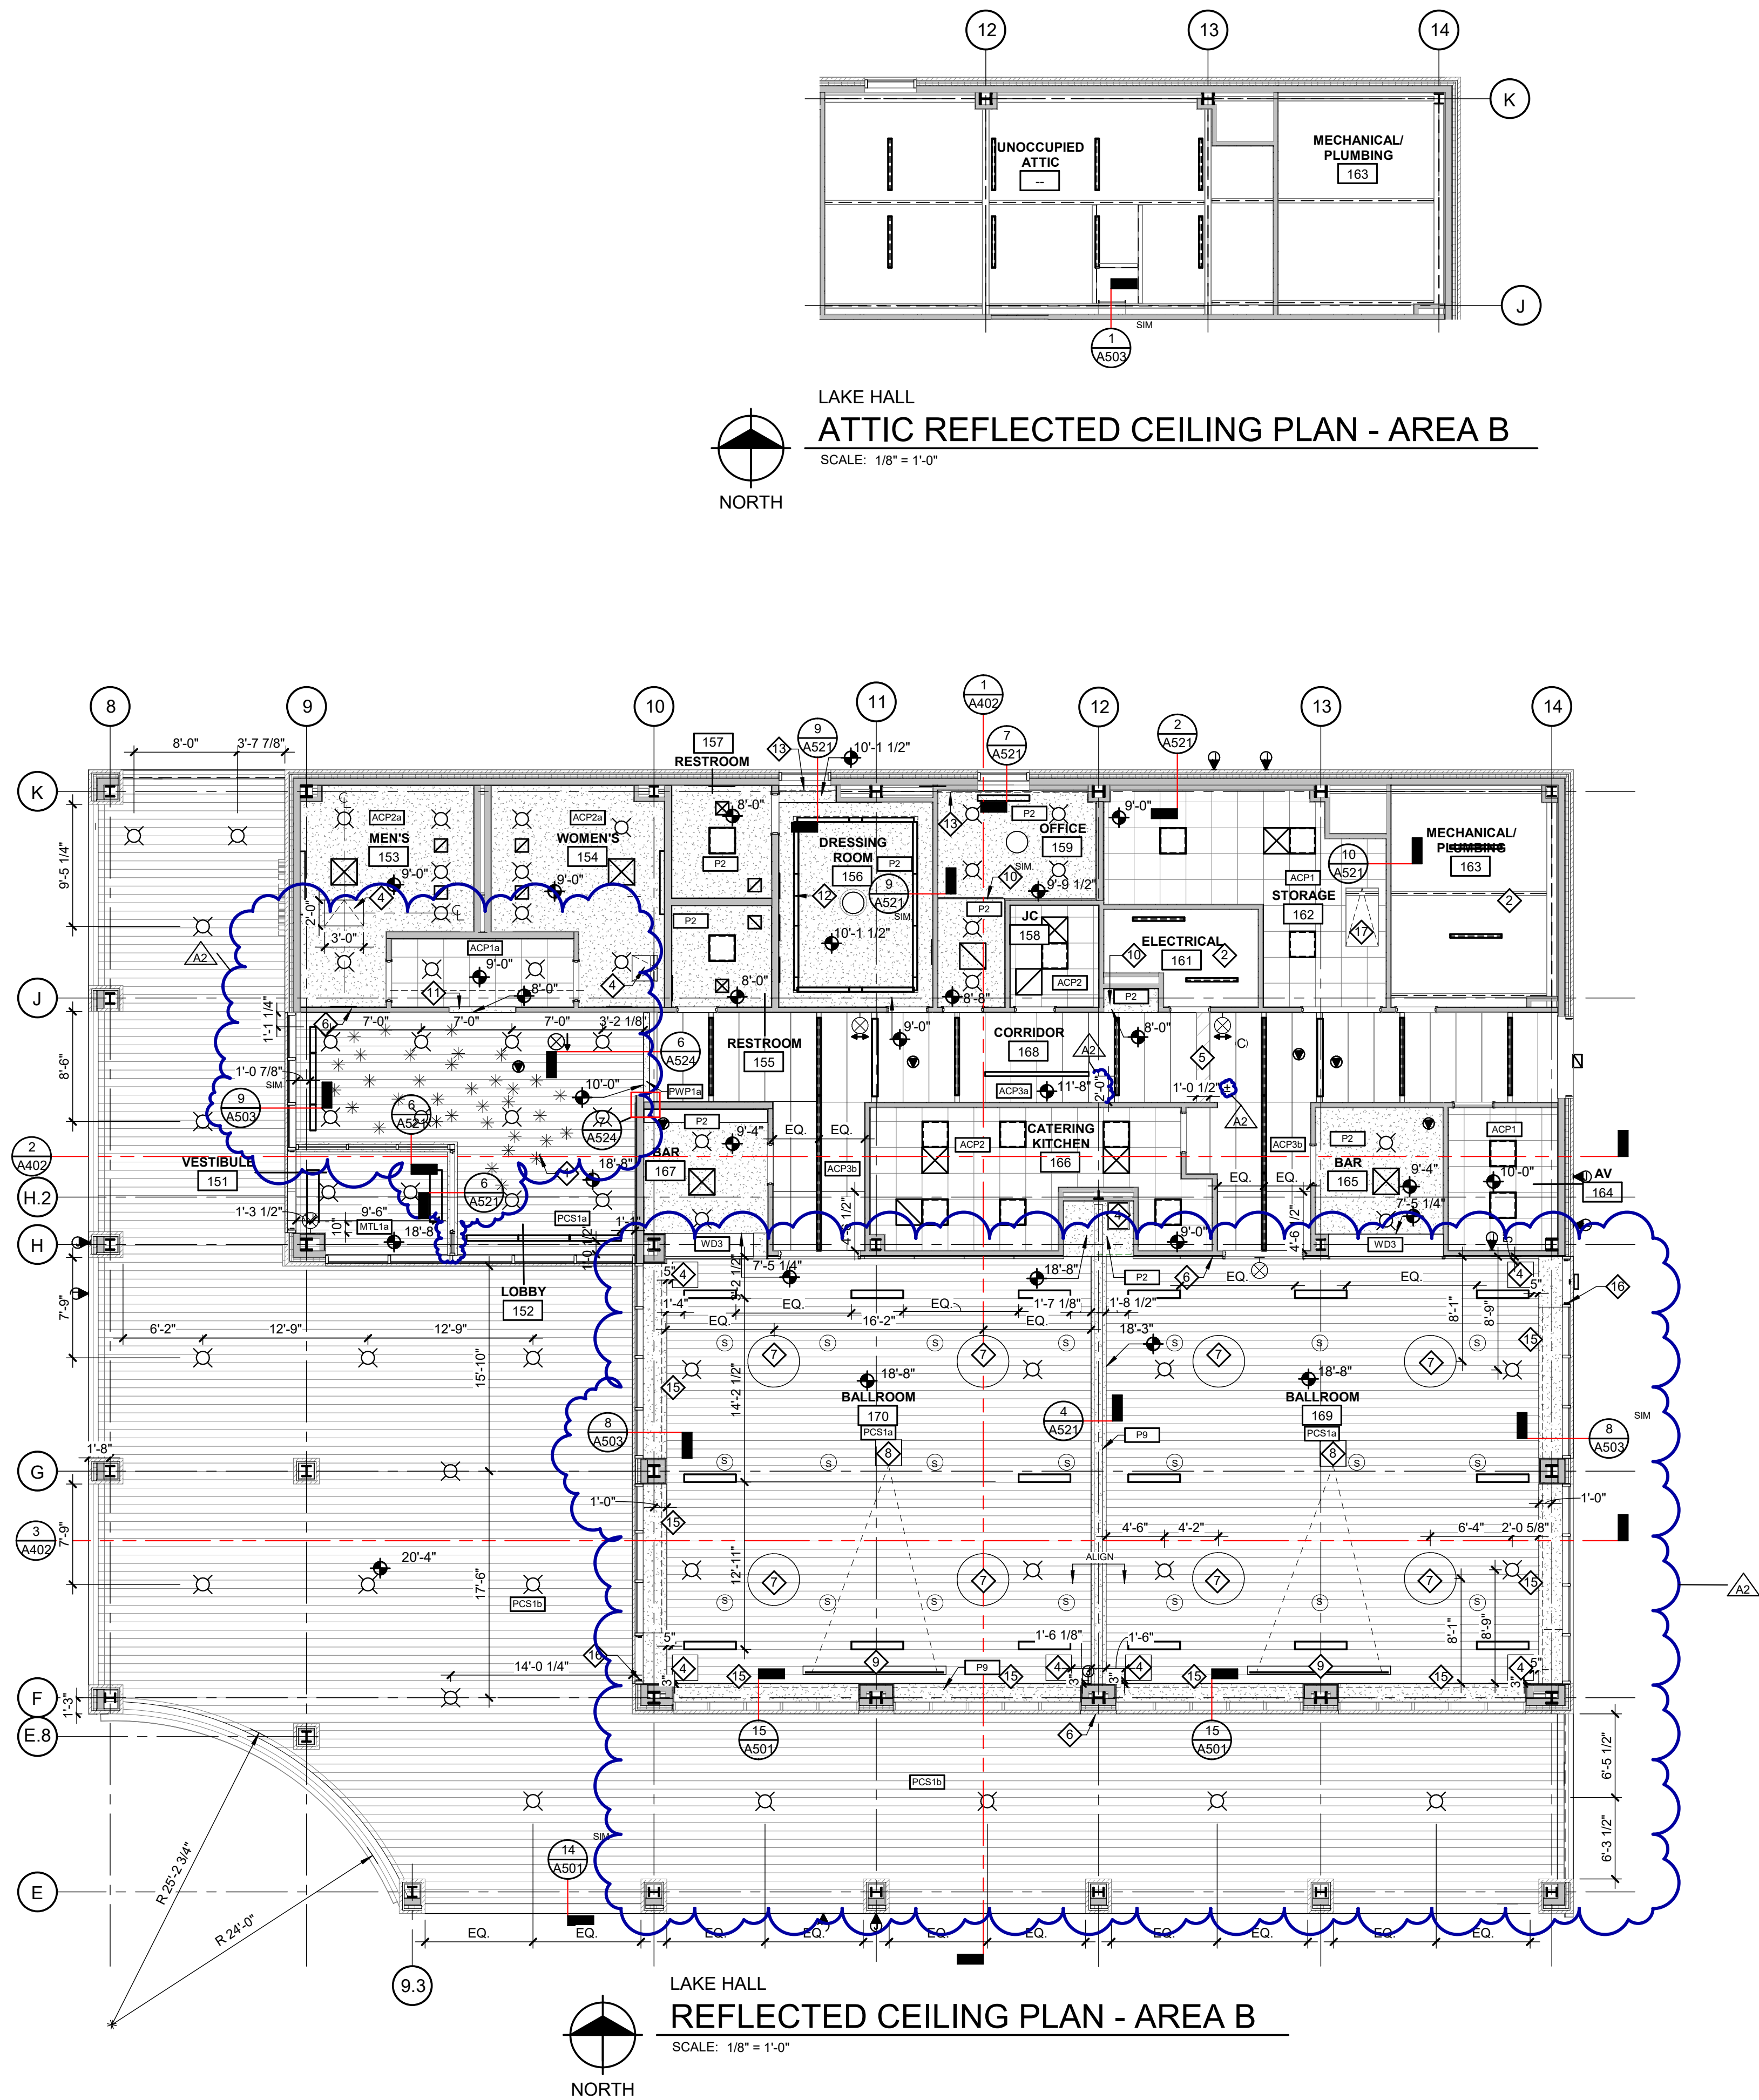

GENERAL REFLECTED CEILING PLAN NOTES

1. ALL CEILING ELEVATIONS ARE ABOVE FINISH FLOOR
 2. ALL CEILING GRIDS ARE TO BE CENTERED ON ROOM / AREA U.N.O
 3. CENTER HVAC DIFFUSERS AND LIGHTING ON METAL CEILING PANELS.
 4. WHERE LIGHT FIXTURES ARE TO BE MOUNTED IN LINEAR METAL CEILINGS, DIMENSION PROVIDED IN REFLECTED CEILING PLANS IS TO BE VERIFIED IN FIELD SO FIXTURE IS LOCATED CENTERED WITHIN AN INDIVIDUAL LINEAR METAL SLAT.
- # KEY NOTES
1. ACOUSTIC ROOM COMPONENTS - MOBILE, LIGHTART ACOUSTIC MOBILE; AIRCRAFT CABLE SUPPORTS WITH FOLDED SQUARE PET SOLA FELT IN COLORS DUNE & DRIFTWOOD
 2. OPEN TO STRUCTURE ABOVE.
 3. ROOF HATCH DOOR.
 4. ACCESS DOOR, 2' X 2' UNLESS OTHERWISE NOTED.
 5. DIAGONAL HATCH; CUT OVERSIZED TILES AS REQUIRED TO CENTER CEILING GRID IN ROOM.
 6. START METAL PLANK CEILING LAYOUT FROM NORTH WALL; MAINTAIN CONSISTENT PLANK ALIGNMENT THROUGHOUT.
 7. DECORATIVE CHANDELIER, REFER TO ELECTRICAL.
 8. PROJECTOR, REFER TO TECHNOLOGY.
 9. PROJECTION SCREEN, REFER TO TECHNOLOGY.
 10. SOFFIT, REFER TO TYPICAL SOFFIT DETAIL 1/A201
 11. BULKHEAD, REFER TO TYPICAL BULKHEAD DETAIL 2/A201
 12. LINE OF CONT. LIGHT COVE AT SOFFIT 5/A524
 13. LINE OF DRAPERY TRACK. TRACK TO EXTEND FULL WIDTH OF WALL. REFER TO SCHEDULES.
 14. LINE OF SOFFIT MOUNTED ROLLER SHADE (DO NOT PUNCTURE OR MOUNT TO WINDOW FRAME), REFER TO SCHEDULES.
 15. LINE OF SOFFIT MOUNTED DOUBLE ROLLER SHADE, REFER TO SCHEDULES.
 16. EGRESS DOOR, BELOW. STOP ROLLER SHADE IN ALIGNMENT WITH OUTSIDE FACE OF DOOR JAMB AND DO NOT EXTEND ROLLER SHADE OVER DOOR.
 17. ATTIC ACCESS HATCH WITH PULL-DOWN LADDER.

KEY PLAN

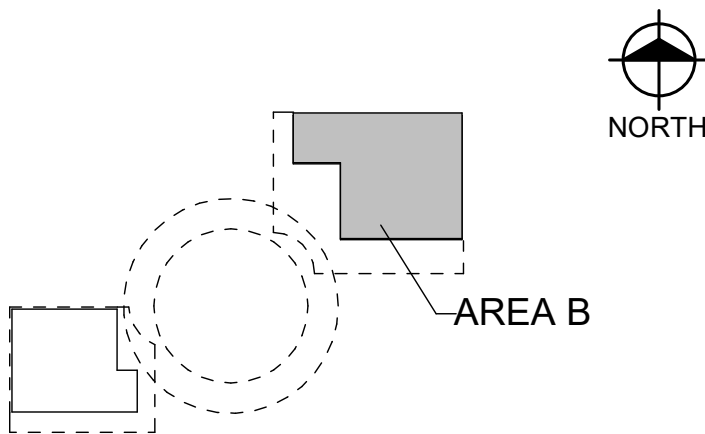

Van Buren Charter Township

Van Buren Township, MI

The Lakeside Park

REVISIONS		
10/27/2026	A2	ADDENDUM NO. 2

10/12/2026	BIDS & PERMIT
09/21/2026	CD PEER REVIEW
09/09/2026	CD TEAM REVIEW
08/10/2026	CD 50% PROGRESS
08/22/2026	DD OWNER REVIEW
06/15/2026	DD PEER REVIEW
06/08/2026	DD 90 % PROGRESS
05/18/2026	DD 90 % PROGRESS
02/23/2026	SD OWNER REVIEW
02/13/2026	SD PEER REVIEW
02/09/2026	SD PROGRESS REVIEW

Drawn By IOLKHOVESKA
Designer IELHENNAWY
Reviewer WLRAPSON
Manager CKRETOVIC

Hard copy is intended to be 24"x36" when plotted. Scale(s) indicated and graphic quality may not be accurate for any other size.

PROJECT NO.
2500281
SHEET NO.

A152

CONSTRUCTION	<div><div>STRUCTURE</div><div>CLG</div><div>6" MIN</div><div>CEILING AS SCHEDULED</div><div>METAL STUDS</div><div>(1) LAYER 5/8" GYP. BD. EA. SIDE, REFER TO SCHEDULE FOR GYP. BD. TYPE</div><div>ACOUSTIC INSULATION AT WALLS WITH "A" SUFFIX ONLY</div><div>FLOOR</div></div>					<div><div>STRUCTURE</div><div>CLG</div><div>6" MIN</div><div>CEILING AS SCHEDULED</div><div>METAL STUDS</div><div>(1) LAYER 5/8" GYP. BD. ONE SIDE</div><div>ACOUSTIC INSULATION AT WALLS WITH "A" SUFFIX ONLY</div><div>FLOOR</div></div>					<div><div>STRUCTURE</div><div>CLG</div><div>CEILING AS SCHEDULED</div><div>METAL STUDS</div><div>(1) LAYER 5/8" F.R.T. PLYWOOD SHEATHING</div><div>(1) LAYER 5/8" ACOUSTICAL SOUND DAMPENING WALL BOARD</div><div>ACOUSTIC INSULATION AT WALLS WITH "A" SUFFIX ONLY</div><div>FLOOR</div></div> <div>WALL PANEL FINISH, REFER TO SCHEDULES</div> <div>ACOUSTIC SEALANT AT ALL JOINTS IN PLYWOOD</div>					<div><div>STRUCTURE</div><div>CLG</div><div>CEILING AS SCHEDULED</div><div>METAL STUDS</div><div>(2) LAYERS 5/8" GYP. BD.</div><div>(1) LAYER 5/8" TYPE "X" GYP. BD. AND (1) LAYER 5/8" ACOUSTICAL SOUND DAMPENING WALL BOARD</div><div>ACOUSTIC INSULATION AT WALLS WITH "A" SUFFIX ONLY</div><div>FLOOR</div></div>					<div><div>STRUCTURE</div><div>CLG</div><div>6" MIN</div><div>CEILING AS SCHEDULED</div><div>(1) LAYER 5/8" GYP. BD. EA. SIDE, REFER TO SCHEDULE FOR GYP. BD. TYPE</div><div>(1) LAYER 1/2" PLYWOOD SHEATHING</div><div>MTL. STUDS</div><div>ACOUSTICAL BATT INSULATION AT WALLS WITH "A" SUFFIX ONLY</div><div>FLOOR</div></div>																												
	A					B					C					D					E																												
LEGEND	TAG	STUD SIZE	TOTAL WIDTH	STC	DESCRIPTION	TAG	STUD SIZE	TOTAL WIDTH	STC	DESCRIPTION	TAG	STUD SIZE	TOTAL WIDTH	STC	DESCRIPTION	TAG	STUD SIZE	TOTAL WIDTH	STC	DESCRIPTION	TAG	STUD SIZE	TOTAL WIDTH	STC	DESCRIPTION																								
	A4	4"	5 1/4"	--	(1) LAYER 5/8" GYPSUM BOARD, EACH SIDE OF 4" METAL STUDS, 33 MIL (MIN.) AT 16" O.C.	B2	2 1/2"	3 1/8"	--	PROVIDE ACOUSTICAL INSULATION WITHIN WALL CAVITY.	C4.A1	4	5 1/4"	46	(1) LAYER OF 5/8" F.R.T. PLYWOOD SHEATHING, 4" METAL STUDS, 33 MIL (MIN.) AT 16" O.C., 4" ACOUSTIC INSULATION, (1) LAYER OF 5/8" THICK ACOUSTICAL SOUND DAMPENING WALL BOARD.	D6.A	6"	8 1/2"	62	(2) LAYERS OF 5/8" GYPSUM BOARD, 6" METAL STUDS, 33 MIL (MIN.) AT 16" O.C., 6" ACOUSTIC INSULATION, (1) LAYER OF 5/8" TYPE "X" GYPSUM BOARD ON 5/8" ACOUSTICAL SOUND DAMPENING WALL BOARD, ACOUSTICAL ASSEMBLY STC PER NATIONAL GYPSUM COMPANY TEST ASSEMBLY NGC2019062.	E4.A	4"	5 3/4"	46	(1) LAYER OF 1/2" PLYWOOD SHEATHING, (1) LAYER OF 5/8" GYPSUM BOARD, 4" METAL STUDS, 33 MIL (MIN.) AT 16" O.C., 4" ACOUSTIC INSULATION, (1) LAYER OF 5/8" TYPE "X" GYPSUM BOARD, ACOUSTICAL ASSEMBLY STC PER NATIONAL GYPSUM COMPANY TEST ASSEMBLY NGC2018106.																								
	A4.A1	4"	5 1/4"	46	(1) LAYER OF 5/8" GYPSUM BOARD, 4" METAL STUDS, 33 MIL (MIN.) AT 16" O.C., 4" ACOUSTIC INSULATION, (1) LAYER OF 5/8" TYPE "X" GYPSUM BOARD, ACOUSTICAL ASSEMBLY STC PER NATIONAL GYPSUM COMPANY TEST ASSEMBLY NGC2018106.	B4	4"	4 5/8"	--	(1) LAYER 5/8" GYP. BOARD, 4" METAL STUDS, 33 MIL (MIN.) AT 16" O.C., 4" ACOUSTIC INSULATION.																																							
	A4.A2	4"	5 1/4"	50	(1) LAYER OF 5/8" THICK ACOUSTICAL SOUND DAMPENING WALL BOARD, 4" METAL STUDS, 33 MIL (MIN.) AT 16" O.C., 4" THICK ACOUSTIC INSULATION, (1) LAYER OF 5/8" THICK ACOUSTICAL SOUND DAMPENING WALL BOARD, ACOUSTICAL ASSEMBLY STC PER NATIONAL GYPSUM COMPANY TEST ASSEMBLY NGC2018004.	B4.A	4"	4 5/8"	--	(1) LAYER 5/8" GYP. BOARD, 4" METAL STUDS, 33 MIL (MIN.) AT 16" O.C., 4" ACOUSTIC INSULATION.																																							
	A6	6"	7 1/4"	--	(1) LAYER 5/8" GYPSUM BOARD, EACH SIDE OF 6" METAL STUDS, 33 MIL (MIN.), AT 16" O.C.	B6	6"	6 5/8"	--	(1) LAYER 5/8" GYP. BOARD, 6" METAL STUDS, 33 MIL (MIN.) AT 16" O.C.																																							
	A6.A1	6"	7 1/4"	46	(1) LAYER OF 5/8" GYPSUM BOARD, 6" METAL STUDS, 33 MIL (MIN.) AT 16" O.C., 6" ACOUSTIC INSULATION, (1) LAYER OF 5/8" TYPE "X" GYPSUM BOARD, ACOUSTICAL ASSEMBLY STC PER NATIONAL GYPSUM COMPANY TEST ASSEMBLY NGC2018106.	B6.A	6"	6 5/8"	--	(1) LAYER 5/8" GYP. BOARD, 6" METAL STUDS, 33 MIL (MIN.) AT 16" O.C., 5" ACOUSTIC INSULATION.																																							
	A6.A2	6"	7 1/4"	50	(1) LAYER OF 5/8" THICK ACOUSTICAL SOUND DAMPENING WALL BOARD, 6" METAL STUD, 33 MIL (MIN.) AT 16" O.C., 6" THICK ACOUSTIC INSULATION, (1) LAYER OF 5/8" THICK ACOUSTICAL SOUND DAMPENING WALL BOARD, ACOUSTICAL ASSEMBLY STC PER NATIONAL GYPSUM COMPANY TEST ASSEMBLY NGC2018004.																																												
<div><div>STRUCTURE</div><div>CLG</div><div>6" MIN</div><div>5/8" GYP. BD. (ALLOWED ABOVE CEILING, ABOVE STONE CLADDING)</div><div>CEILING AS SCHEDULED</div><div>5/8" CEMENTITIOUS BACKER BOARD</div><div>METAL STUDS</div><div>3/4" STONE CLADDING</div><div>FLOOR</div></div> <div>CONTINUE GYP BOARD TO STRUCTURE ABOVE</div>																																																	
<div><div>STRUCTURE</div><div>CLG</div><div>6" MIN</div><div>5/8" GYP. BD. (ALLOWED ABOVE CEILING, ABOVE STONE CLADDING)</div><div>CEILING AS SCHEDULED</div><div>5/8" CEMENTITIOUS BACKER BOARD</div><div>METAL STUDS</div><div>3/4" STONE CLADDING</div><div>FLOOR</div></div> <div>CONTINUE GYP BOARD TO STRUCTURE ABOVE</div>																																																	
F																																																	
TAG	STUD SIZE	TOTAL WIDTH	STC	DESCRIPTION																																													
F4	4"	5 5/8"	--	4" METAL STUDS, 33 MIL (MIN.) AT 16" O.C., 5/8" CEMENTITIOUS BACKER BOARD (ABOVE CEILING 5/8" GYPSUM BOARD IS ALLOWED), 3/4" STONE CLADDING.																																													
F6	6"	7 5/8"	--	6" METAL STUDS, 33 MIL (MIN.) AT 16" O.C., 5/8" CEMENTITIOUS BACKER BOARD (ABOVE CEILING 5/8" GYPSUM BOARD IS ALLOWED), 3/4" STONE CLADDING.																																													

STUD SIZE "6"

AB

LOCATION OF TAG INDICATES SIDE OF WALL W/ GYPSUM BOARD OR SIDE OF WALL WITH MULTIPLE LAYERS OF GYPSUM BOARD

PARTITION "A"

WALL TYPE LEGEND

1. WALL TAG WITH "A" SUFFIX INDICATES ACOUSTICAL WALL, REFER TO ACOUSTICAL WALL NOTES BELOW.

2. PROVIDE DEFLECTION TRACKS OR CLIPS FOR ALL PARTITIONS ABUTTING STRUCTURE ABOVE.

3. INTERIOR METAL STUD PARTITIONS ARE DIMENSIONED FROM FACE OF GYPSUM BOARD OR TILE BACKER BOARD.

4. WHERE THICKNESS VARIES BETWEEN TWO PARTITIONS IN AN UNINTERRUPTED CONTINUOUS WALL PLANE, OFFSET STUDS AND ALIGN FACE OF PARTITIONS.

5. METAL STUD FRAMING: MIN. 20 GAGE @ 16" O.C., U.N.O.

6. BEHIND WALL TILE PROVIDE 5/8" CEMENT BOARD IN LIEU OF GYP. BOARD. HOLD TOP OF CEMENT BOARD 1/2" BELOW TOP OF TILE.

7. EXTEND ALL WALLS TIGHT TO DECK ABOVE UNLESS NOTED OR DETAILED OTHERWISE.

8. OFF-SET ALL RECESSED DEVICES BY MINIMUM OF ONE STUD CAVITY. DO NOT INSTALL BACK TO BACK OR WITHIN SAME STUD CAVITY.

9. PROVIDE BLOCKING IN WALL REQ'D TO SUPPORT BUILT-IN ITEMS, FIXTURES, MILLWORK, AND OTHER WALL SUPPORTED ITEMS.

10. PROVIDE IMPACT RESISTANT GYPSUM BOARD FROM FLOOR TO 8'-0" A.F.F. IN LIEU OF REGULAR GYPSUM BOARD OR TYPE X GYPSUM BOARD ON WALLS WITHIN CORRIDORS.

11. WHERE ACOUSTICAL SOUND DAMPENING WALL BOARD IS SCHEDULED

2 BULKHEAD DETAIL

SCALE: 1" = 1'-0"

 
1 SOFIT DETAIL

SCALE: 1" = 1'-0"

TYPICAL TOP OF WALL DETAIL

SCALE: NOT TO SCALE

WALL TYPE NOTES



WALL TYPE LEGEND

- WALL TAG WITH "A" SUFFIX INDICATES ACOUSTICAL WALL, REFER TO ACOUSTICAL WALL NOTES BELOW.
- PROVIDE DEFLECTION TRACKS OR CLIPS FOR ALL PARTITIONS ABUTTING STRUCTURE ABOVE.
- INTERIOR METAL STUD PARTITIONS ARE DIMENSIONED FROM FACE OF GYPSUM BOARD OR TILE BACKER BOARD.
- WHERE THICKNESS VARIES BETWEEN TWO PARTITIONS IN AN UNINTERRUPTED CONTINUOUS WALL PLANE, OFFSET STUDS AND ALIGN FACE OF PARTITIONS.
- METAL STUD FRAMING: MIN. 20 GAGE @ 16" O.C., U.N.O.
- BEHIND WALL TILE PROVIDE 5/8" CEMENT BOARD IN LIEU OF GYP. BOARD. HOLD TOP OF CEMENT BOARD 1/2" BELOW TOP OF TILE.
- EXTEND ALL WALLS TIGHT TO DECK ABOVE UNLESS NOTED OR DETAILED OTHERWISE.
- OFF-SET ALL RECESSED DEVICES BY MINIMUM OF ONE STUD CAVITY. DO NOT INSTALL BACK TO BACK OR WITHIN SAME STUD CAVITY.
- PROVIDE BLOCKING IN WALL REQ'D TO SUPPORT BUILT-IN ITEMS, FIXTURES, MILLWORK, AND OTHER WALL SUPPORTED ITEMS.
- PROVIDE IMPACT RESISTANT GYPSUM BOARD FROM FLOOR TO 8'-0" A.F.F. IN LIEU OF REGULAR GYPSUM BOARD OR TYPE X GYPSUM BOARD ON WALLS WITHIN CORRIDORS.
- WHERE ACOUSTICAL SOUND DAMPENING WALL BOARD IS SCHEDULED ON WALLS THAT ARE SHARED BETWEEN A CORRIDOR AND INTERIOR ROOM, THE ACOUSTICAL SOUND DAMPENING WALL BOARD IS TO BE INSTALLED ON THE INTERIOR ROOM SIDE OF THE WALL.
- AT WALL TYPES WITH NATIONAL GYPSUM COMPANY TEST ASSEMBLY: STUD DEPTH AND MIL THICKNESS (MIN.) AS LISTED IN WALL TYPE SCHEDULE IS REQUIRED IN LIEU OF TESTED ASSEMBLY STUD DEPTH AND MIL THICKNESS.
- AT WALLS WITH TILE OR STONE CLADDING FINISH ON ONE SIDE WITH OTHER SIDE OF STUD BEING UNFINISHED (NON-COMPOSITE WALL; WALL TYPES B AND F), PROVIDE FULL BRACING OR BRACING 48" O.C. AS REQUIRED TO MEET ALLOWABLE SPAN AND DEFLECTION AS SPECIFIED.

- 14 WHERE WALLS ARE INDICATED ON A102 TO BE COLD FORMED METAL FRAMED WALLS FOR SUPPORT OF ATTIC FLOOR SYSTEM, METAL FRAMING TO BE 12 GAUGE MIN.

ACOUSTICAL WALL NOTES (WALLS INDICATED WITH "A" SUFFIX)

- INSULATION IN STUD CAVITY TO COMPLETELY FILL THE CAVITY WITHOUT OVER COMPRESSION.
- NON-RATED PARTITIONS TO HAVE ACOUSTICAL SEALANT AT THE HEAD, SILL, THROUGH PENETRATIONS, OPENINGS AND JOINTS BETWEEN DISSIMILAR MATERIALS.


REVISONS	
10/27/2026	A2 ADDENDUM NO. 2

10/12/2026	BIDS & PERMIT
09/21/2026	CD PEER REVIEW
09/09/2026	CD TEAM REVIEW
08/10/2026	CD 50% PROGRESS
08/22/2026	DD OWNER REVIEW
08/15/2026	DD PEER REVIEW
08/08/2026	DD 90 % PROGRESS
08/18/2026	DD 90 % PROGRESS
02/23/2026	SD OWNER REVIEW
02/13/2026	SD PEER REVIEW
02/09/2026	SD PROGRESS REVIEW




Drawn By	IOLKHOVESKA
Designer	LFINNEY
Reviewer	WLRAPSON
Manager	CKRETOVIC

Hard copy is intended to be 24"x36" when plotted. Scale(s) indicated and graphic quality may not be accurate for any other size.

 PROJECT NO.
2500281
SHEET NO.



DOOR SCHEDULE NOTES:	
1	NOT USED.
2	NOT USED.
3	FROSTED GLASS.
4	CONCEALED / INVISIBLE HINGE DOOR WITH ACOUSTIC WOOD PANEL FINISH (WWP1) ON ROOM 105 SIDE.
5	DOOR TO RECEIVE CARD READER, REFER TO TELECOMMUNICATION DRAWINGS, ELECTRICAL DRAWINGS, AND HARDWARE SETS.
6	TOP OF DOOR FRAME TO BE 8'-0" TO ALIGN MASONRY COURSING. VERIFY FINAL DOOR HEIGHT WITH ENTRANCE DOOR MANUFACTURER.
7	DOOR IS TO BE SIZED TO FIT WITHIN MULLION DESIGN LOCATIONS. VERIFY FINAL DOOR SIZES WITH MULLION LOCATIONS AND ENTRANCE DOOR MFR.
8	WEST LEAF IS ACTIVE LEAF.
9	SOUTH LEAF IS ACTIVE LEAF.
10	NOT USED.
11	NORTH LEAF IS ACTIVE LEAF.
12	NOT USED.

   

PLOT INFO: 10/27/2026 2:55:49 PM Autodesk Docs://250281 - Van Buren Twp Lake House/2026_A_250281.rvt

FINISH LEGEND

ACP1	ACOUSTIC PANEL CEILING MFR: ARMSTRONG PRODUCT: CALLA 2824 COLOR: WHITE SIZE: 24" X 24" X 1" THICK EDGE: SQUARE TEGULAR GRID: 15/16" PRELUDE XL ACOUSTICS: 0.85 NRC / 35 CAC ECOLABLE: DECLARE CONTACT: SARA KUCHTA, 586 940 5121 skuchta@armstrong.com	FB1	FABRIC (MOVABLE PARTITION) MFR: CARGIE CONTENT: 100% XOREL PATTERN: TANGLE 6213W COLOR: 8 WIDTH: 56" WEIGHT: 10.1OZ ECOLABLE: BIOBASED CONTENT, PVC-FREE, LIVING PRODUCT	Q1	QUARTZ (DRESSING RM COUNTER) MFR: WILSONART COLOR: HALDI Q4032 THICKNESS: 3CM	TL2	GLASS MOSAIC TILE MFR: DAL TILE PRODUCT: CASCADING WATERS COLOR: CW40 SHIMMER SHORE SIZE: 4 X RANDOM STRAIGHT STACK INSTALLATION: MOSAIC SHEET FINISH: POLISHED GROUT: MAPEI, ULTRACOLOR PLUS FA, 5014 BISCUIT, MATCH WIDTH BETWEEN TILES ON SHEET	WC1	WALLCOVERING MATERIAL: VINYL MFR: WOLF GORDON COLLECTION: RAMPART FLEXIBLE WALL PROTECTION PATTERN: GRAIN GOH 34809018 COLOR: BEECH WIDTH: 52"W
ACP2	ACOUSTIC PANEL CEILING MFR: ARMSTRONG PRODUCT: SCHOOL ZONE FINE FISSURE 1810 COLOR: WHITE SIZE: 24" X 24" X 3/4" THICK EDGE: SQUARE LAY-IN GRID: 15/16" PRELUDE XL ACOUSTICS: 0.70 NRC / 40 CAC ECOLABLE: DECLARE CONTACT: SARA KUCHTA, 586 940 5121 skuchta@armstrong.com	FLM1	GLASS FILM MFR: SOLYX PRODUCT: XS1309 FINE CRYSTAL FROST NOTE: PROVIDE FULL HEIGHT MOCK-UP FOR OWNER REVIEW	Q2	QUARTZ (RESTROOM SINKS) MFR: CORIAN COLOR: VENETIA CREAM	TL3	PORCELAIN TILE MFR: PLATFORM SURFACES PRODUCT: CONCAVA COLOR: WINTER BLUE SIZE: 4.5" X 9" INSTALLATION: HORIZONTAL STACKED GLOSSY GROUT: MAPEI, ULTRACOLOR PLUS FA, 5093 WARM GRAY	WC2	NOT USED
ACP3a	ACOUSTIC PANEL CEILING (HALL CORRIDOR) MFR: ARMSTRONG PRODUCT: TECHZONE 4" PANELS: LYRA PB VECTOR 8497PB COLOR: WHITE SIZE: 24" X 96" X 7/8" THICK EDGE: 15/16" VECTOR W/ 1/4" REVEAL GRID: 15/16" PRELUDE XL ACOUSTICS: 0.90 NRC ECOLABLE: DECLARE CONTACT: SARA KUCHTA, 586 940 5121 skuchta@armstrong.com	FWP1	FABRIC WRAPPED WALL PANELS MFR: KINETICS PRODUCT: HARDSIDE W/ ECONETIC CORE SIZE: 2"D FABRIC: CARGIE PATTERN: DOVER 6123 COLOR: 12 ECOLABLE: BIOBASED CONTENT, PVC-FREE, LIVING PRODUCT	RB1	RUBBER BASE MFR: TARKETT TYPE: JOHNSONITE BASEWORKS MILLWORK PROFILE: REVEAL, MX-XX-F THICKNESS: 0.25" COLOR: 672 ASHEN SIZE: 4.25"H ECOLABLE: NON-PVC, CRADLE TO CRADLE SILVER	TL4	PORCELAIN TILE (EXTERIOR RESTROOM WALLS) MFR: DWYER PRODUCT: CORE PATTERN: QUARTZITE QU-001 SIZE: 12X24, 8MM THICK COLOR: AVORIO FINISH: MATTE INSTALLATION: VERTICALLY STACKED GROUT: MAPEI, ULTRACOLOR PLUS FA, IVORY CONTACT: MORGAN KLINE, 616.644.9362 MORGAN.KLINE@DWYERMARBLE.COM	WC3	WALLCOVERING (ACCENT) MFR: IMAGE360 CONTENT: VINYL PATTERN: CUSTOM SUBSTRATE: GF 229 WALLMARK CANVAS 6.0 MIL MATTE WHITE EMBOSSED VINYL PRODUCT PRODUCED AND INSTALLED BY IMAGE360
ACP3b	ACOUSTIC PANEL CEILING (HALL CORRIDOR) MFR: ARMSTRONG PRODUCT: TECHZONE 4" PANELS: LYRA PB VECTOR 8496PB COLOR: WHITE SIZE: 24" X 72" X 7/8" THICK EDGE: 15/16" VECTOR W/ 1/4" REVEAL GRID: 15/16" PRELUDE XL ACOUSTICS: 0.90 NRC ECOLABLE: DECLARE CONTACT: SARA KUCHTA, 586 940 5121 skuchta@armstrong.com	FWP2	FABRIC WRAPPED WALL PANELS MFR: KINETICS PRODUCT: HARDSIDE W/ ECONETIC CORE SIZE: 2"D FABRIC: CARGIE PATTERN: DOVER 6123 COLOR: 12 ECOLABLE: BIOBASED CONTENT, PVC-FREE, LIVING PRODUCT	SSM1	SOLID SURFACE (RECEPTION & BAR) MFR: LX HAUSYS PRODUCT: EARTHWORKS COLOR/PTRN: STRATA CREAM	TL5a	PORCELAIN PANEL MFR: ENVI SURFACES PRODUCT: TRIBUTE COLOR: GLORY SIZE: 126X60", 12MM FINISH: POLISHED SLAB CONTACT: MORGAN KLINE, 616.644.9362 MORGAN.KLINE@DWYERMARBLE.COM	WC4	WALLCOVERING (DRESSING & OFFICE) MFR: INNOVATIONS CONTENT: VINYL PATTERN: ILLUMINA COLOR: ILL-08 WHITE DIAMOND WIDTH: 54" REPEAT: NON-MATCH BACKING: OSNABURG WEIGHT: 200z
AP1	ACOUSTIC PANEL (FOCUS ROOM) MFR: SLALOM PRODUCT: ECoRange PROFILE: WAVE SIZE: 51.2Wx 110.2Hx1.77" THICK BACKING: 40MM FABRIC: BOUCLE, 5038 CHAMPAGNE ACOUSTICS: 0.90 NRC ECOLABLE: DECLARE CONTACT: SUSAN HALL, 248.241.6000 SUSAN@ECOSURROUNDINGS.ECO	PCS1a	LINEAR METAL PLANK CEILING SYSTEM (INTERIOR) MFR: ARMSTRONG CEILINGS PRODUCT: METALWORKS LINEAR CLASSIC SIZE: 96" X 8" X 5/8" THICK COLOR: EFFECTS CHERRY FXCH PERF: PERFORATED NOTE: ACOUSTIC FIBERGLASS INFILL BACKING: .85 NRC CONTACT: SARA KUCHTA, 586 940 5121 skuchta@armstrong.com	STN1	STONE NATURAL STONE CLADDING, MATCH EXTERIOR STONE IN COLOR & PATTERN MFR: EARTHWORKS NOTE: REFER TO STONE CLADDING SPEC	TL5b	PORCELAIN PANEL (WALL CLADDING) MFR: ENVI SURFACES PRODUCT: TRIBUTE COLOR: GLORY SIZE: 126X60", 6MM FINISH: POLISHED SLAB CONTACT: MORGAN KLINE, 616.644.9362 MORGAN.KLINE@DWYERMARBLE.COM	WD1	WOOD (TYPICAL WOOD DOORS) MFR: FORTE SPECIES: WHITE MAPLE CUT: PLAIN SLICED FINISH: ENGLISH SADDLE
AP2	ACOUSTIC PANEL (MEETING ROOM) MFR: SLALOM PRODUCT: ECoRange PROFILE: MILLERIGHE SIZE: 52.2Wx 110.2Hx0.43" THICK BACKING: 40MM FABRIC: VELVET, 666 DARK BLUE ACOUSTICS: 0.90 NRC ECOLABLE: DECLARE CONTACT: SUSAN HALL, 248.241.6000 SUSAN@ECOSURROUNDINGS.ECO	PCS1b	LINEAR METAL PLANK CEILING SYSTEM (EXTERIOR) MFR: ARMSTRONG CEILINGS PRODUCT: METALWORKS LINEAR CLASSIC SIZE: 96" X 8" X 5/8" THICK COLOR: EFFECTS CHERRY FXCH2 PERF: UNPERFORATED CONTACT: SARA KUCHTA, 586 940 5121 skuchta@armstrong.com	TL1a	PORCELAIN TILE (INTERIOR) MFR: ERGON PRODUCT: ELEGANCE PRO COLOR: IVORY SIZE: 47-1/4" x 47-1/4" x 9.5MM FINISH: NATURAL R10 RECTT. SEE PLAN GROUT: 1/8"W MAPEI, ULTRACOLOR PLUS FA, 5039 IVORY	TPN1	TOILET PARTITIONS MFR: IRONWOOD PRODUCT: ELEMENT SERIES, MODEL 100093 MATERIAL: HPL LAMINATE LAMINATE: MATCH PL1 CONTACT: AARON MAHELONA 425.249.1911 SPECS@IRONWOOD-MFG.COM	WD2	WOOD (BALLROOM DOORS AND MILLWORK) MFR: DOOGEE VENEERS SPECIES: RECON LINEAR RIFT WHITE OAK CUT: RIFT CUT MATCH: SLIP LOG: 3414859-12
AP3	WALLCOVERING (DIGITAL MURAL ON ACOUSTIC PANEL) MATERIAL: PET PANEL MFR: MOMENTUM TYPE: CUBE PANEL W/ DIGITAL PRINT GRAPHIC MATERIAL: 100% POLYESTER THICKNESS: 1" SIZE: 48" X 111" PATTERN: WHISPERS IN MOTION DIGITAL PRINT COLOR: PAVILION CONTACT: BRANDI WEISS, 313.720.2871 BWEISS@MOMTEX.COM	P1	PAINT (TYPICAL WALL) MFR: BENJAMIN MOORE COLOR: OC-131 WHITE DOWN	TL1b	PORCELAIN TILE (OUTDOOR PAVER) MFR: ERGON PRODUCT: ELEGANCE PRO COLOR: IVORY SIZE: 18" x 36" x 20MM FINISH: R11 RECTT. PATTERN: SEE PLAN CONTACT: MICHAEL MONTORSI,(630)935-6450, MMONTORSI@M2ILTD.COM	TS1	TRANSITION STRIP (TILE/CARPET) MFR: SCHLUTER STRIP PRODUCT: SCHIENE MATERIAL: STAINLESS STEEL	WD3	WOOD (RECEPTION DESK) TYPE: TAMBOUR FLEXIBLE WOOD SHEET MFR: DESIGNS OF DISTINCTION PRODUCT: FLEXIBLE TAMBOUR PROFILE: 101 SIZE: 3/4" BEAD, 0.313 THICK SPECIES: WHITE OAK FINISH: SITE FINISH WITH CLEAR SEALER
CPT1	CARPET TILE MFR: SHAW PRODUCT: SPOKEN TILE 5T406 COLOR: SCRIPT 05210 SIZE: 9 X 18" INSTALLATION: ASHLAR BACKING: ECOWORX TILE FIBER/DYE: 100% SOLUTION DYED NYLON ECOLABLE: CRADLE TO CRADLE SILVER DECLARE RED LIST FREE CONTACT: ASHLEY HAZEL 616.980.7391 ASHLEY.HAZEL@SHAWCONTRACT.COM	P2	PAINT (TYPICAL CEILING) MFR: SHERWIN WILLIAMS COLOR: SW7005 PURE WHITE	TL1c	PORCELAIN TILE MFR: ERGON PRODUCT: ELEGANCE PRO COLOR: IVORY SIZE: 11-13/16" X 23-5/8" x 9.5MM FINISH: NATURAL R10 RECTT. SEE PLAN GROUT: 1/8"W MAPEI, ULTRACOLOR PLUS FA, 5039 IVORY	TS2	TRANSITION STRIP (FLOOR/WALL COVE TRANSITION) MFR: SCHLUTER STRIP PRODUCT: COVE SHAPED BASE DILEX-EHK MATERIAL: STAINLESS STEEL FINISH: BRUSHED	WD4a	WOOD (INTERIOR NANAWALL FINISH) MFR: NANAWALL COLOR: CHERRY #100 FINISH: STANDARD FACTORY CLEAR FINISH
CPT2	CARPET TILE MFR: INTERFACE PRODUCT: DIGITIZED TUFT 139380AK00 COLOR: NEUTRAL 105981 SIZE: 25CM X 1M INSTALLATION: ASHLAR BACKING: GLASBAC TILE FIBER/DYE: 100% SOLUTION DYED NYLON CONTENT: SHELBE OGBURN, 616.370.6087 SHELBE.OGBURN@INTERFACE.COM	P3	PAINT MFR: SHERWIN WILLIAMS COLOR: SW6204 SEA SALT	TL1d	PORCELAIN TILE (WALL, TEXTURED) MFR: ERGON PRODUCT: ELEGANCE PRO, MURAL COLOR: IVORY SIZE: 23-5/8" x 47-1/4" x 9.5MM FINISH: MURAL NATURAL R10 RECTT. PATTERN: SEE ELEVATIONS GROUT: 1/8"W MAPEI, ULTRACOLOR PLUS FA, 5039 IVORY	TS3	TRANSITION STRIP (EXTERIOR RESTROOMS COVE) MFR: SCHLUTER STRIP PRODUCT: COVE SHAPED BASE DILEX-AHKA MATERIAL: STAINLESS STEEL FINISH: BRUSHED NOTE: AT TILE WALL/CONCRETE FLOOR	WD4b	WOOD (MILLWORK TRIM AT INTERIOR NANAWALL) MFR: MATCH WD4a
CPT3	CARPET RUG MFR: SHAW PRODUCT: FAULT 5A221 COLOR: ALABASTER GOLD 20111 SIZE: 13'X9', 12'X12', 7'X10' SEE PLANS FOR LOCATIONS, GOODS: 12 INSTALLATION: BROADLOOM, BOUND EDGES BACKING: ULTRALOC FIBER/DYE: 100% SOLUTION DYED NYLON ECOLABLE: CRADLE TO CRADLE SILVER NOTE: BIND EDGES FOR RUG APPLICATION CONTACT: ASHLEY HAZEL 616.980.7391 ASHLEY.HAZEL@SHAWCONTRACT.COM	P4	PAINT MFR: SHERWIN WILLIAMS COLOR: SW0069 ROSE TAN	TL1e	PORCELAIN TILE (WALL, BASE) MFR: ERGON PRODUCT: ELEGANCE PRO, BATTISCOPA COLOR: IVORY SIZE: 2-3/4" X 23-5/8" x 9.5MM FINISH: NATURAL R10 RECTT. ALIGN WITH FLOORING GROUT: SUJDE CONTACT: MICHAEL MONTORSI,(630)935-6450, MMONTORSI@M2ILTD.COM	TS4	TRANSITION STRIP (FIREPLACE EDGE) MFR: SCHLUTER STRIP PRODUCT: SATIN ANODIZED ALUMINUM	WS1	WINDOW SHADE TYPE: ROLLER SHADE MFR: MECOHSHADE STYLE: TWO SINGLE ROLLS, ELECTRIC SHD CLOTH 1: LIGHT-FILTERING: SOHO 1600, 3% OPEN COLOR: 1603 LIGHT GREY SHD CLOTH 2: ACOUSTIC ROOM-DARKENING: ACOUSTVEIL, COLOR: 0893 PEARL GREY CLOSURE COLOR: SWF BRONZE CONTACT: ANGELA RHODE, AMERICAN INTERIORS 734.624.8173, arohde@amininteriors.com
CPT4	WALK-OFF CARPET MFR: SHAW PRODUCT: 60745 WELCOME II COLOR: 31761 PORTABELLA SIZE: 12' BACKING: ULTRALOC ECOLABLE: CRI GREEN LABEL PLUS CONTACT: ASHLEY HAZEL 616.980.7391 ASHLEY.HAZEL@SHAWCONTRACT.COM	P5	PAINT MFR: SHERWIN WILLIAMS COLOR: SW9179 ANCHORS AWEIGH	TL1f	PORCELAIN TILE MFR: ERGON PRODUCT: ELEGANCE PRO COLOR: IVORY SIZE: 23-5/8" x 47-1/4" x 9.5MM FINISH: NATURAL R10 RECTT. SEE ELEVATIONS GROUT: 1/8"W MAPEI, ULTRACOLOR PLUS FA, 5039 IVORY	VP1	VENETIAN PLASTER MFR: COLOR ATELIER PRODUCT: VENETIAN LIME PLASTER COLOR: WABI COATS: 3 COAT SCRATCH-BODY-TOP, LAYERED AND BURNISHED FINISH: SELED TOP COAT: SELED MOVEMENT: CROSS-HATCH PATTERN WITH LONG & SWEEPING STROKES NOTE: INTENT FOR EXPRESSED GENTLE TROWEL MARKS EMPHASIZING DEPTH SPENCER KASTEN, (616)403-1836, SPENCERKASTEN@GMAIL.COM	WS2	WINDOW SHADE (DRAPEY) TYPE: DRAPE, SHEER MFR: CARNEGIE PATTERN: HALINA 36915 COLOR: 336 WIDTH: 128" CONTENT: 100% TREVIRA CS POLYESTER STYLE: RIPPLEFOLD FULLNESS: 120% DRAW: BATON, ONE-WAY, BUTTMASTER HEM: BEAD WEIGHTED EUROHEM NOTE: FABRIC MUST BE RAILROADED CONTACT: ANGELA RHODE, AMERICAN INTERIORS 734.624.8173, arohde@amininteriors.com
CONC-SL	CONCRETE - SEALED REFER TO SPEC	P6	PAINT MFR: SHERWIN WILLIAMS COLOR: SW7044 AMAZING GRAY	TL1g	PORCELAIN TILE MFR: ERGON PRODUCT: ELEGANCE PRO COLOR: IVORY SIZE: 5-7/8" x 47-1/4" x 9.5MM FINISH: NATURAL R10 RECTT. SEE FINISH PLAN GROUT: 1/8"W MAPEI, ULTRACOLOR PLUS FA, 5039 IVORY	WB1	WOOD BASE, PAINTED TYPE: WOOD SIZE: 4TH FINISH: PAINTED TO MATCH WALL OR AS NOTED	WWP1	WOOD (WOOD WALL PANELS, ACOUSTIC) MFR: TERRA MIA TYPE: THIN SLAT ACOUSTIC WALL PANELS (SKU2797) SIZE: 1"wx12" THICK WOOD SLAT ON BACKER, 7/8" TOTAL THICK, 12" FACE WIDTH, 7-10 1/2" FIXED LENGTHS SPECIES: BLACK WALNUT FINISH: FACTORY FINISHED LOW-VOC MATTE POLYURETHANE BACKING: RECYCLED PET FELT PANEL, BLACK ACOUSTICS: 0.50 SAA, 0.50 NRC, CONTACT: MITCH GREENBURG, MITCH@TERRAMA.COM, 312.618.6070

GENERAL FINISH NOTES

- GENERAL:
 - REFER TO INTERIOR ELEVATIONS FOR ADDITIONAL FINISH INFORMATION.
- FLOORING:
 - ADDITIONAL FLOORING MATERIAL IN DIRECTION INDICATED ON FINISH PLAN, UNLESS NOTED OTHERWISE.
 - PROVIDE CEMENTITIOUS COMPOUND BETWEEN FLOOR MATERIALS OF DIFFERENT THICKNESS. FEATHER FLOOR FOR SMOOTH TRANSITION.
 - USE TRANSITION STRIPS WHERE INDICATED ON FINISH LEGEND.
 - FLOORING TRANSITIONS TO TAKE PLACE AT CENTER OF DOOR IN CLOSED POSITION.
 - TRANSITIONS:
 - TILE/CARPET = TS1
 - CARPET/CONCRETE = TS5
 - TILE/CONCRETE = TS6
- EXPOSED STRUCTURE:
 - EXPOSED STEEL ADJACENT TO GLASS CURTAIN WALL SHALL BE P11
- SOFFITS:
 - PAINT ALL SOFFIT FACE AND UNDERSIDES TO MATCH ADJACENT WALL COLOR.
- DIFFUSERS AND COVERS:
 - PAINT ALL WALL DIFFUSERS AND AIR GRILLE COVERS TO MATCH ADJACENT WALL COLOR.
- COUNTERTOPS:
 - TYPICAL QUARTZ SURFACE COUNTERTOP EDGE PROFILE TO BE 3CM EASED EDGE.
 - PORCELAIN COUNTER TOPS EDGE TO BE MITERED
 - SOLID SURFACE COUNTER TOPS EDGE TO BE 1/8" EASED.
- RESTROOM SINK SYSTEM ROOMS 108, 109, 111, 153, 154, 155, 157:
 - TOP MATERIAL: QUARTZ Q1
 - APRON: 4.75"H
 - EDGE: STRAIGHT
 - FIXTURES: BRUSHED NICKEL
 - PIPE ENCLOSURE: ANGLED LAMINATE, SEE ELEVATIONS
- CEILINGS:
 - REFER TO REFLECTED CEILING PLAN AND LEGEND FOR CEILING TYPES, FINISH DESIGNATION AND LOCATIONS.
 - CEILING SYSTEM ACCESS PANELS SHALL CONTINUE PATTERN OF CEILING WITHOUT INTERRUPTION OF A FRAME AROUND THE PANEL EDGE.
- INTERIOR STONE VENEER WALLS AND COLUMNS:
 - AT ALL INTERIOR WALLS AND COLUMNS CLAD IN STONE VENEER, THE STONE SHALL CONTINUE TO THE FLOOR. DO NOT APPLY ROOM SPECIFIED BASE AT THESE LOCATIONS.
 - THE STONE COLOR AND PATTERN SHALL MATCH AND CONTINUE FROM THE EXTERIOR.

Van Buren Charter Township

Van Buren Township, MI

The Lakeside Park

REVISIONS		
10/27/2026	A2	ADDENDUM NO. 2

10/12/2026	BIDS & PERMIT
09/21/2026	CD PEER REVIEW
09/09/2026	CD TEAM REVIEW
08/10/2026	CD 50% PROGRESS
08/22/2026	DD OWNER REVIEW
08/15/2026	DD PEER REVIEW
08/08/2026	DD 90 % PROGRESS
08/18/2026	DD 90 % PROGRESS
02/23/2026	SD OWNER REVIEW
02/13/2026	SD PEER REVIEW
02/09/2026	SD PROGRESS REVIEW

Drawn By	IOLKHOVESKA
Designer	KBRAUN
Reviewer	WLRAPSON
Manager	CKRETOVIC

Hard copy is intended to be 24"x36" when plotted. Scale(s) indicated and graphic quality may not be accurate for any other size.

PROJECT NO.
2500281


SHEET NO.

A203


PLOT INFO: 10/27/2026 2:55:57 PM Autodesk Docs://2500281 - Van Buren Twp Lake House/2026_A_2500281.rvt

KEY NOTES


- 1" INSULATED SPANDREL GLAZING UNIT (INDICATED BY SOLID GRAY HATCH).
- NANAWALL ALUMINUM SERIES 640L.

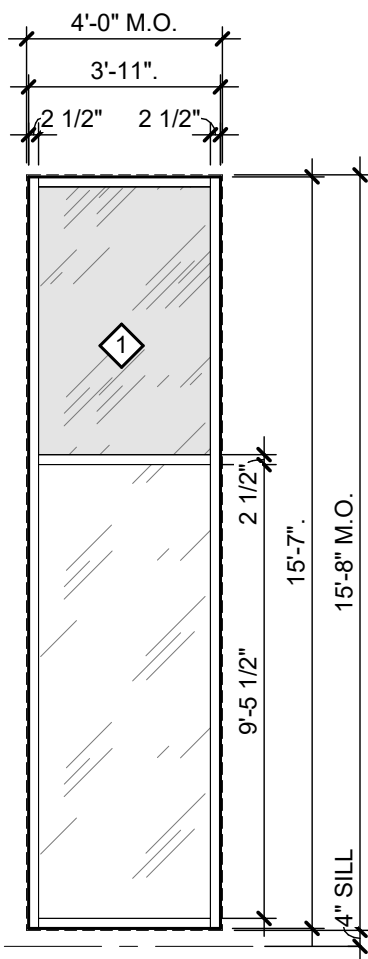


12 CW-A7 CURTAIN WALL
SCALE: 1/4" = 1'-0"

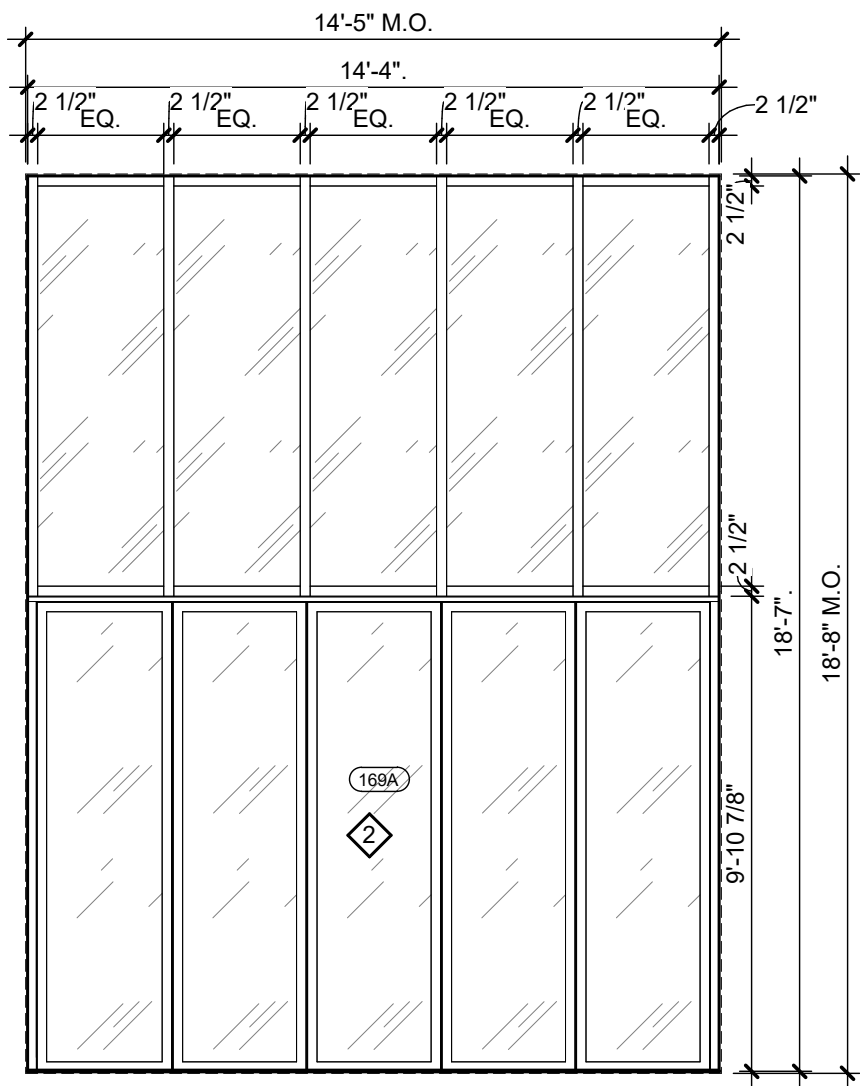


11 CW-B5 CURTAIN WALL
SCALE: 1/4" = 1'-0"

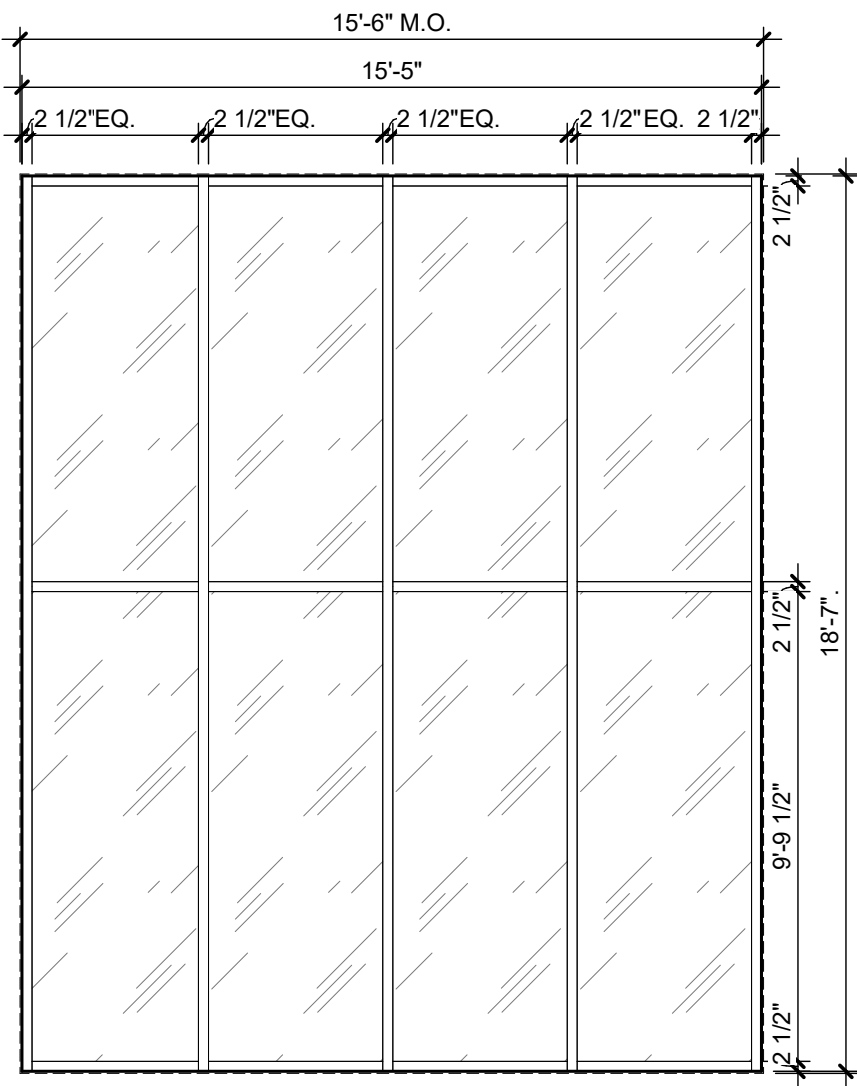


10 CW-B4 CURTAIN WALL
SCALE: 1/4" = 1'-0"

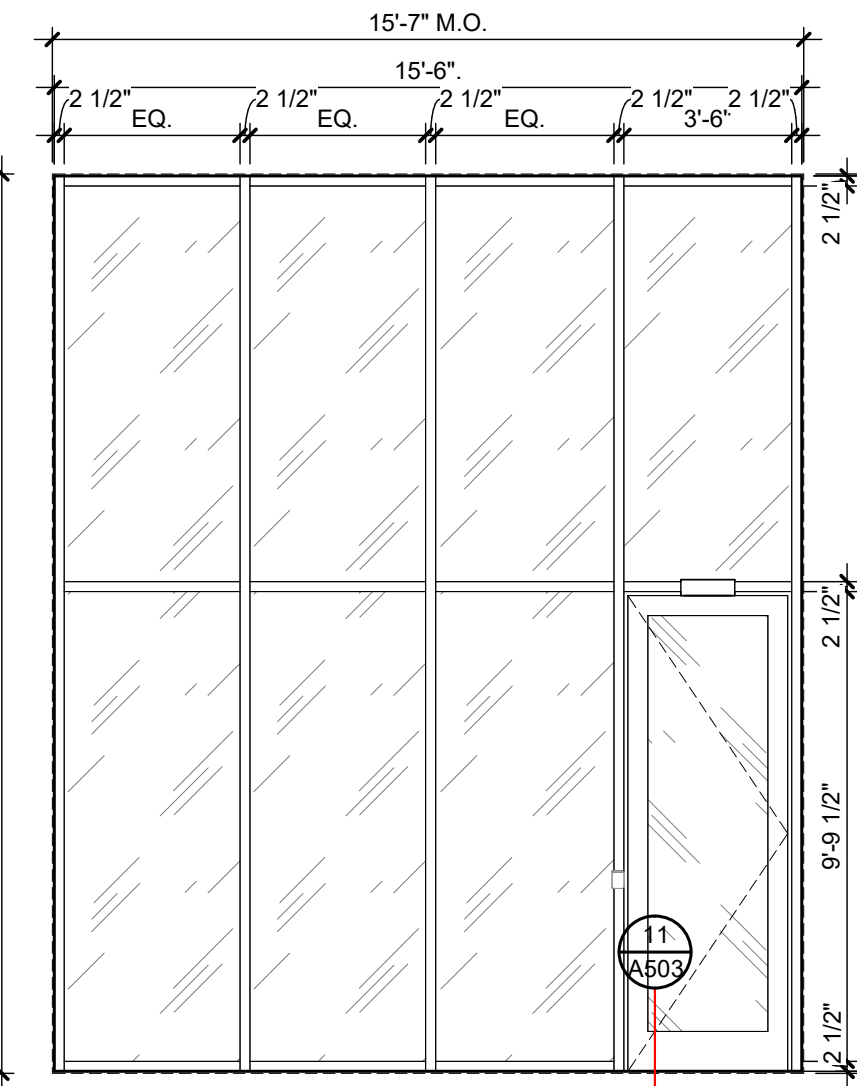


9 CW-B3 CURTAIN WALL
SCALE: 1/4" = 1'-0"

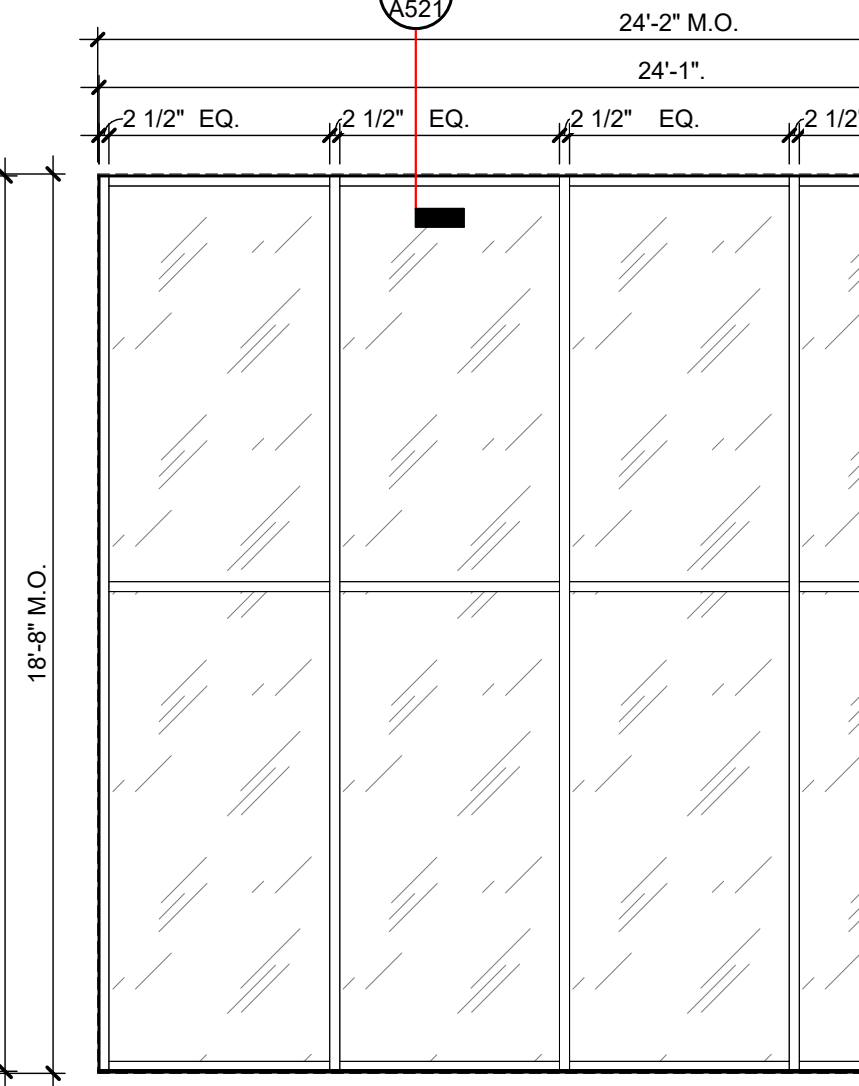


8 CW-B2 CURTAIN WALL
SCALE: 1/4" = 1'-0"

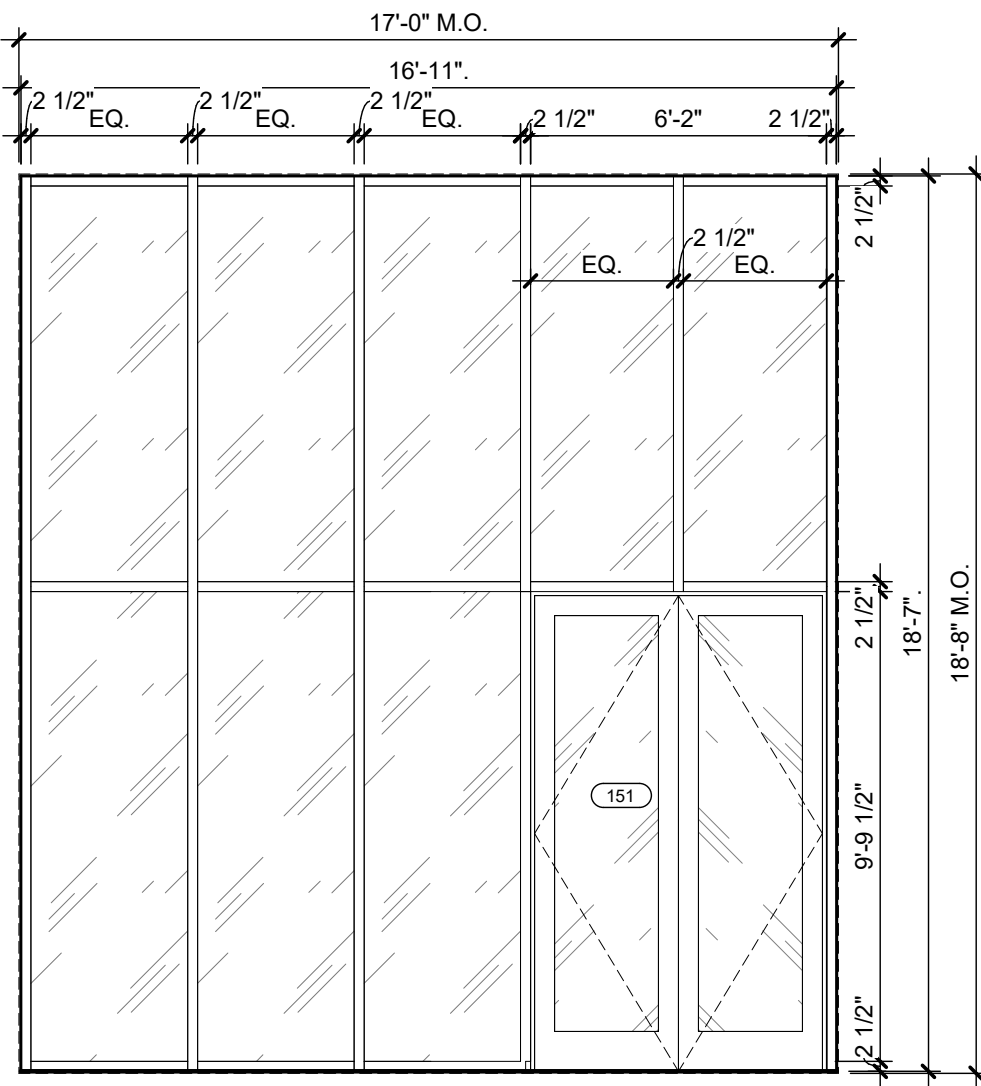


7 CW-B1 CURTAIN WALL
SCALE: 1/4" = 1'-0"

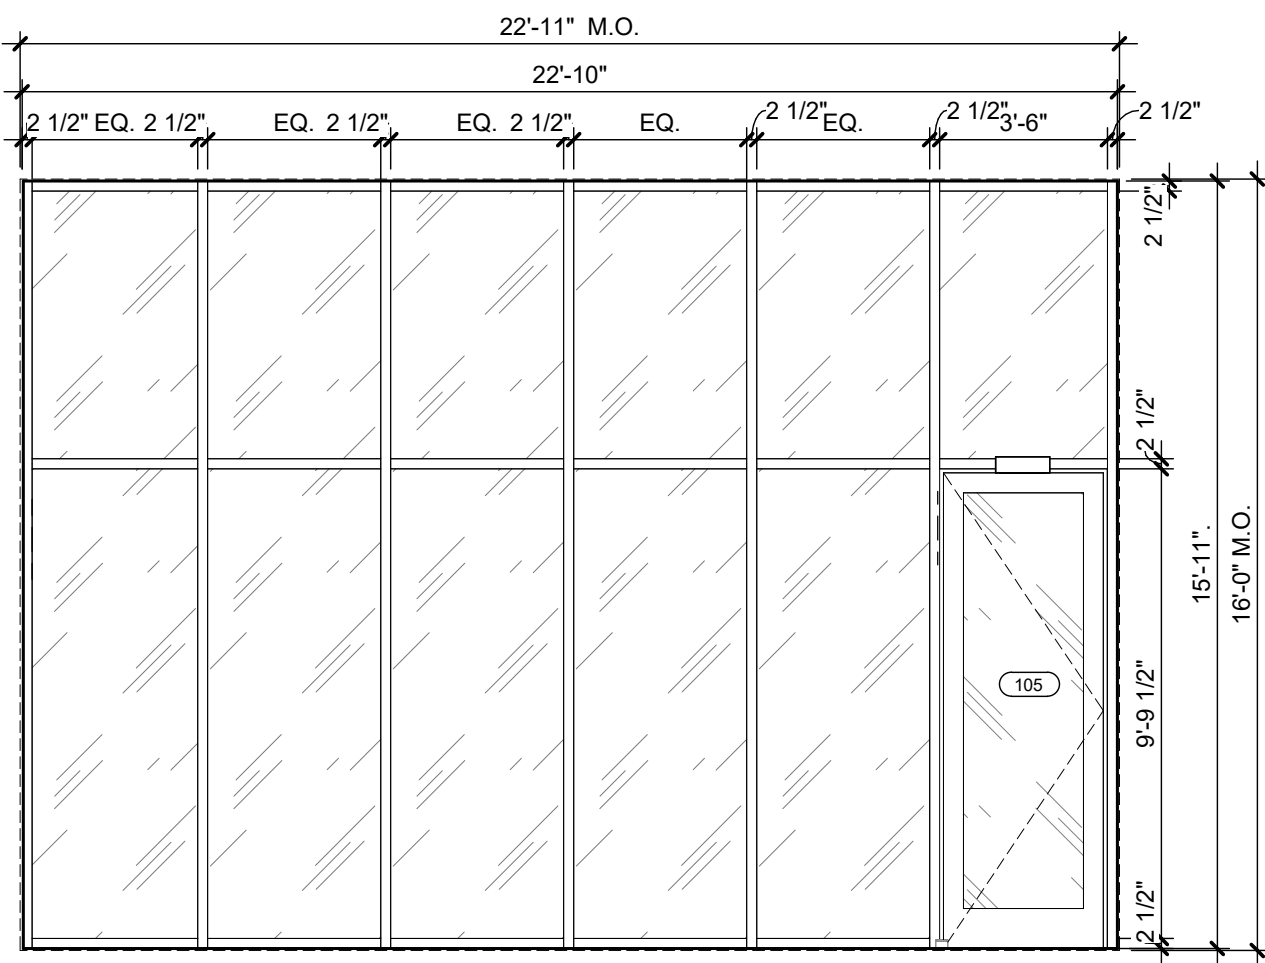


6 CW-A6 CURTAIN WALL
SCALE: 1/4" = 1'-0"

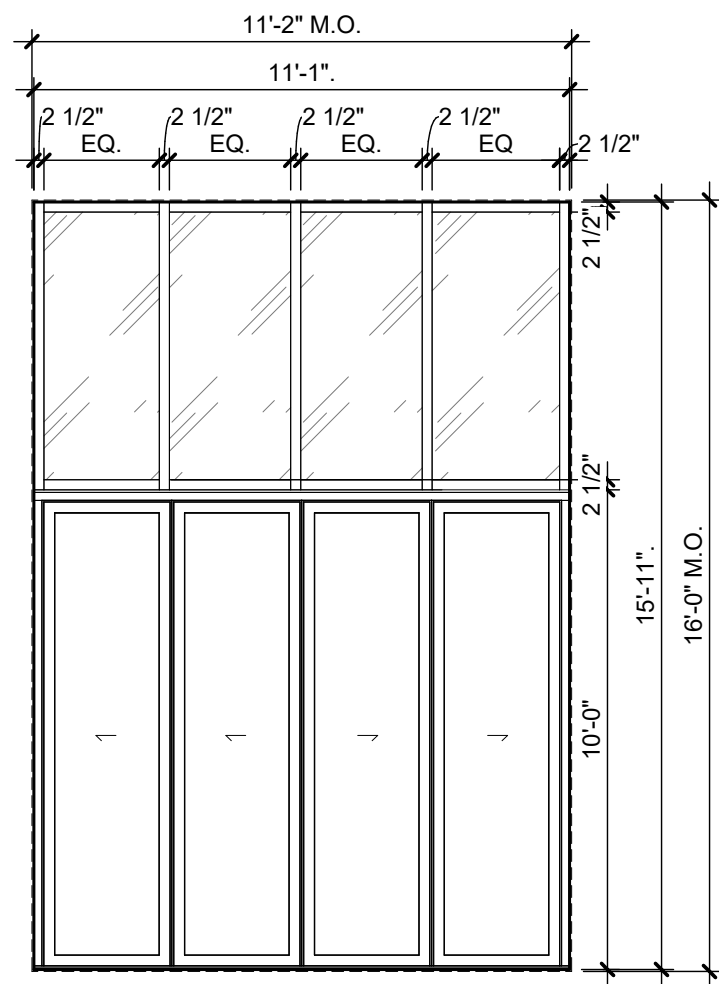


5 CW-A5 CURTAIN WALL
SCALE: 1/4" = 1'-0"

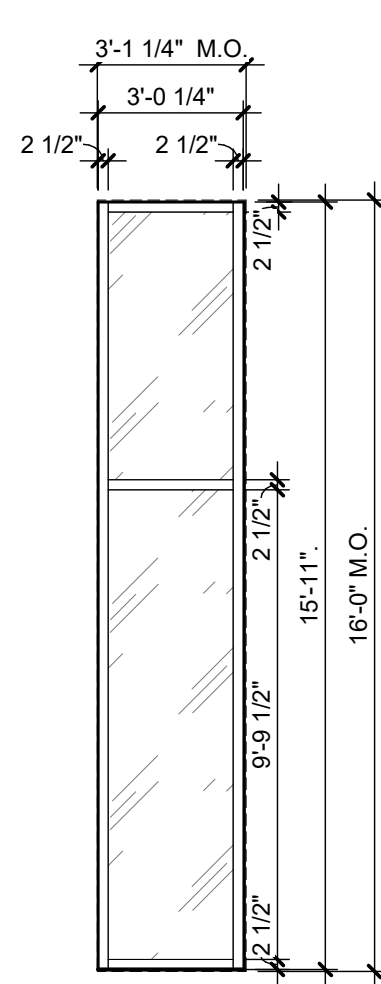


4 CW-A4 CURTAIN WALL
SCALE: 1/4" = 1'-0"

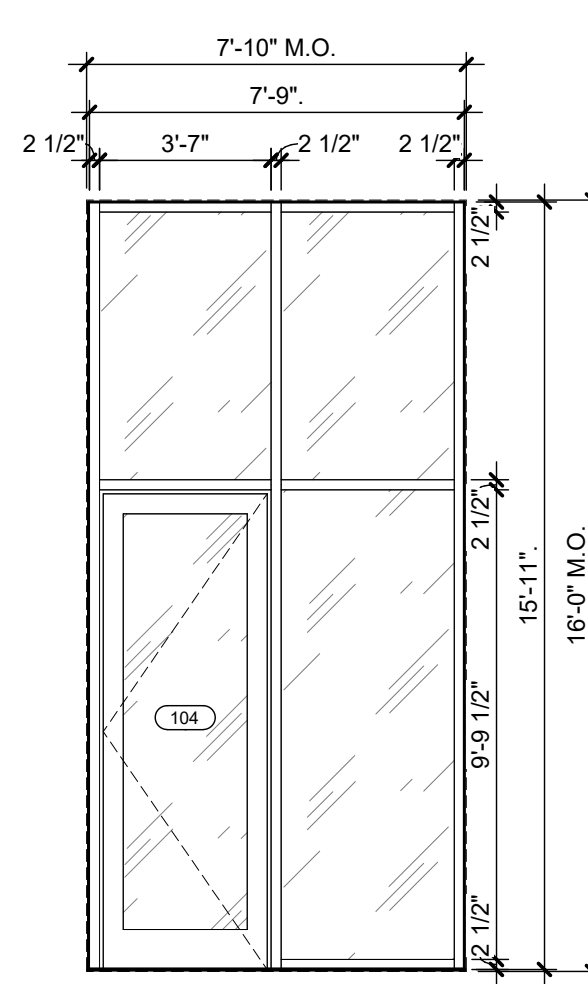


3 CW-A3 CURTAIN WALL
SCALE: 1/4" = 1'-0"

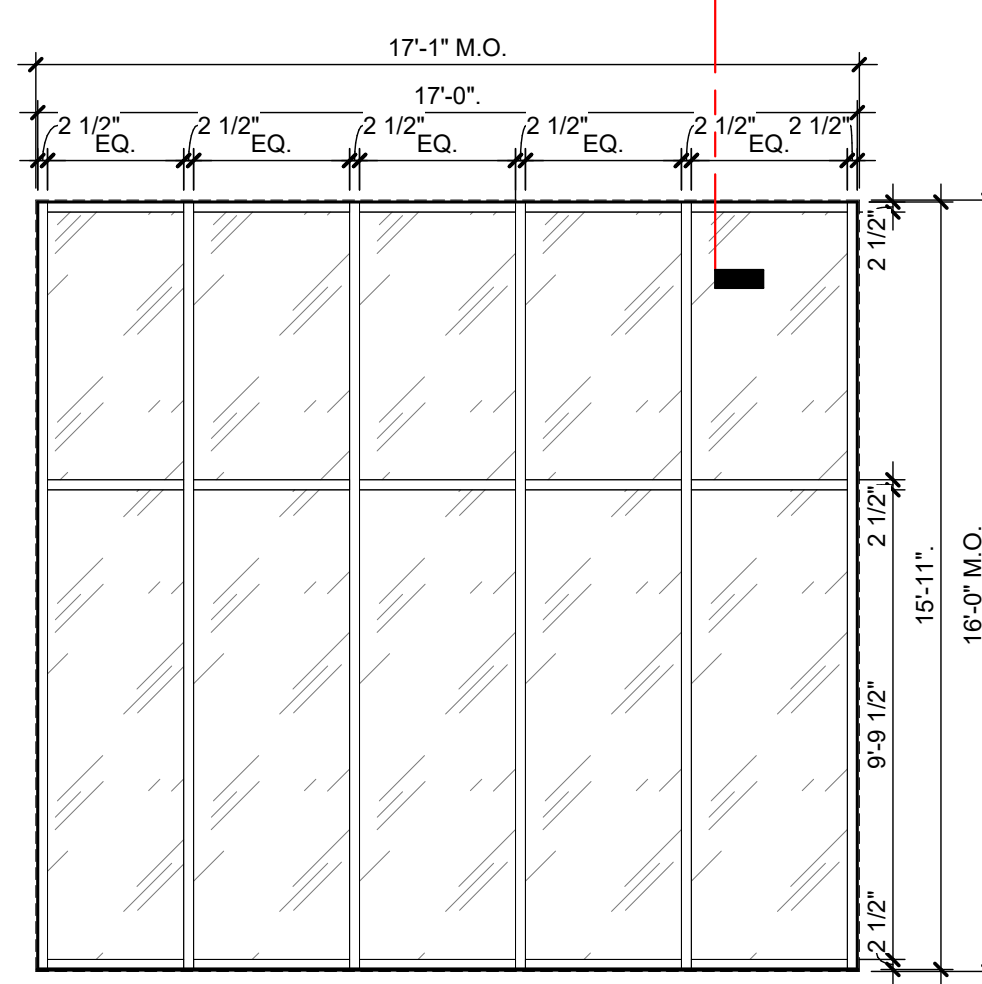


2 CW-A2 CURTAIN WALL
SCALE: 1/4" = 1'-0"

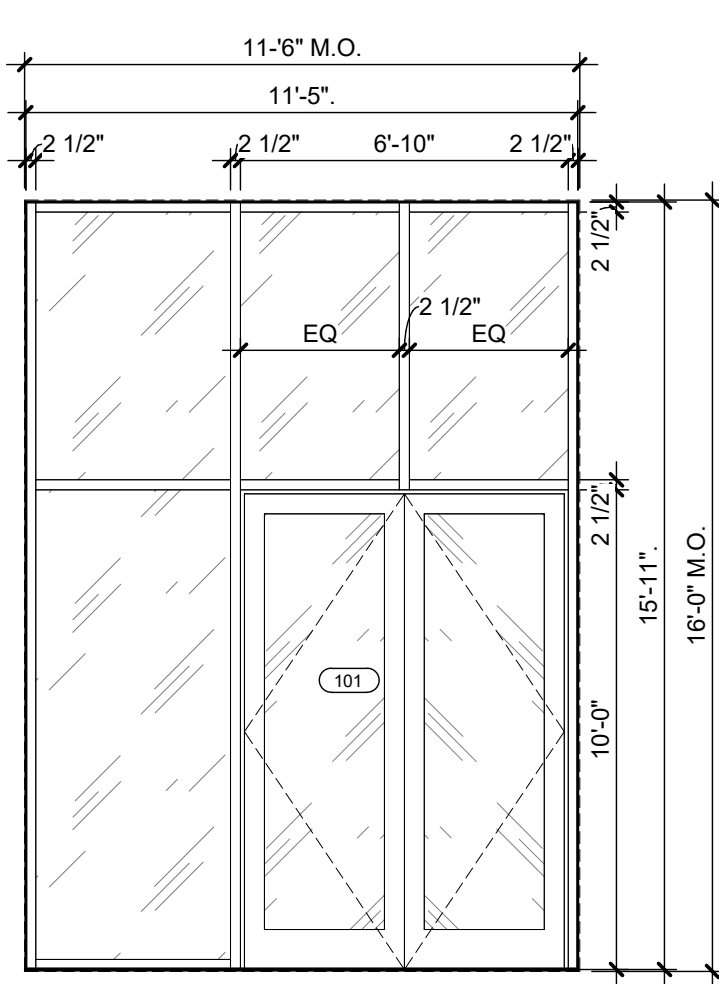


1 CW-A1 CURTAIN WALL
SCALE: 1/4" = 1'-0"

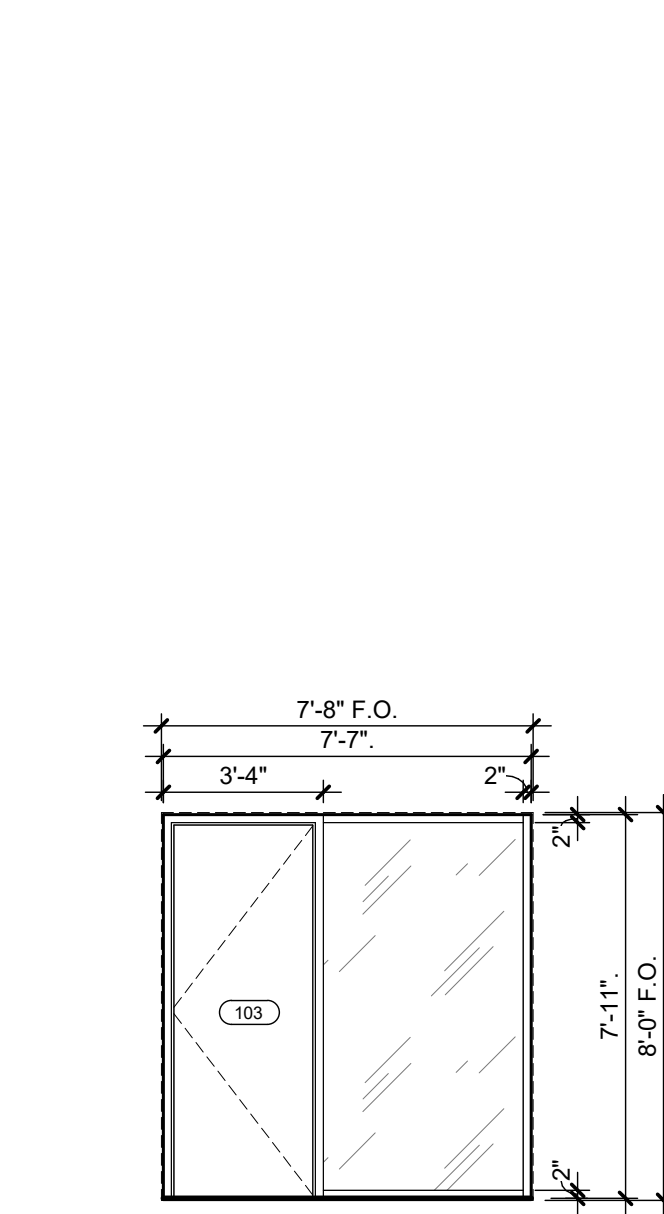


17 SF-A2 INTERIOR
SCALE: 1/4" = 1'-0"

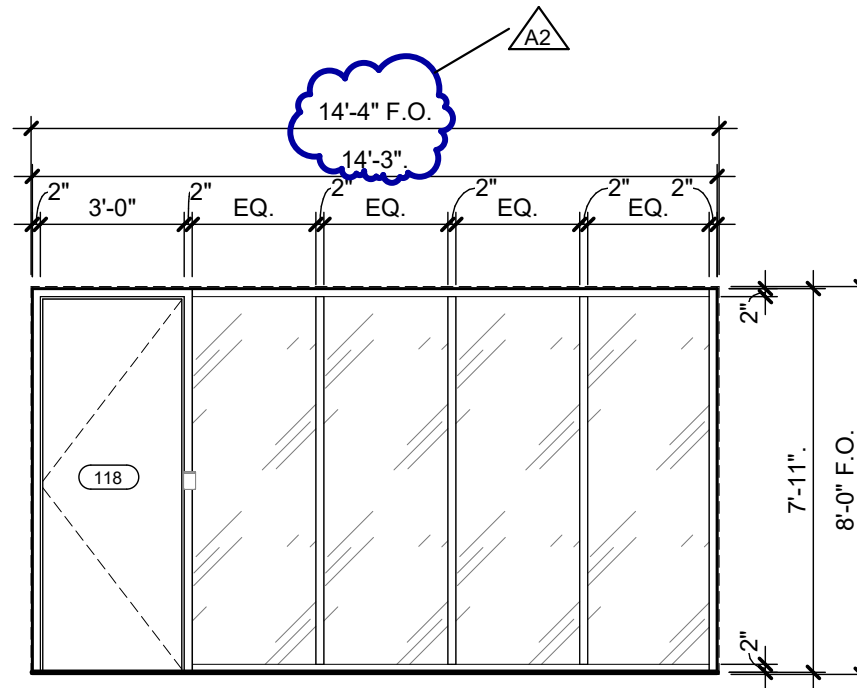


16 SF-A3 INTERIOR
SCALE: 1/4" = 1'-0"

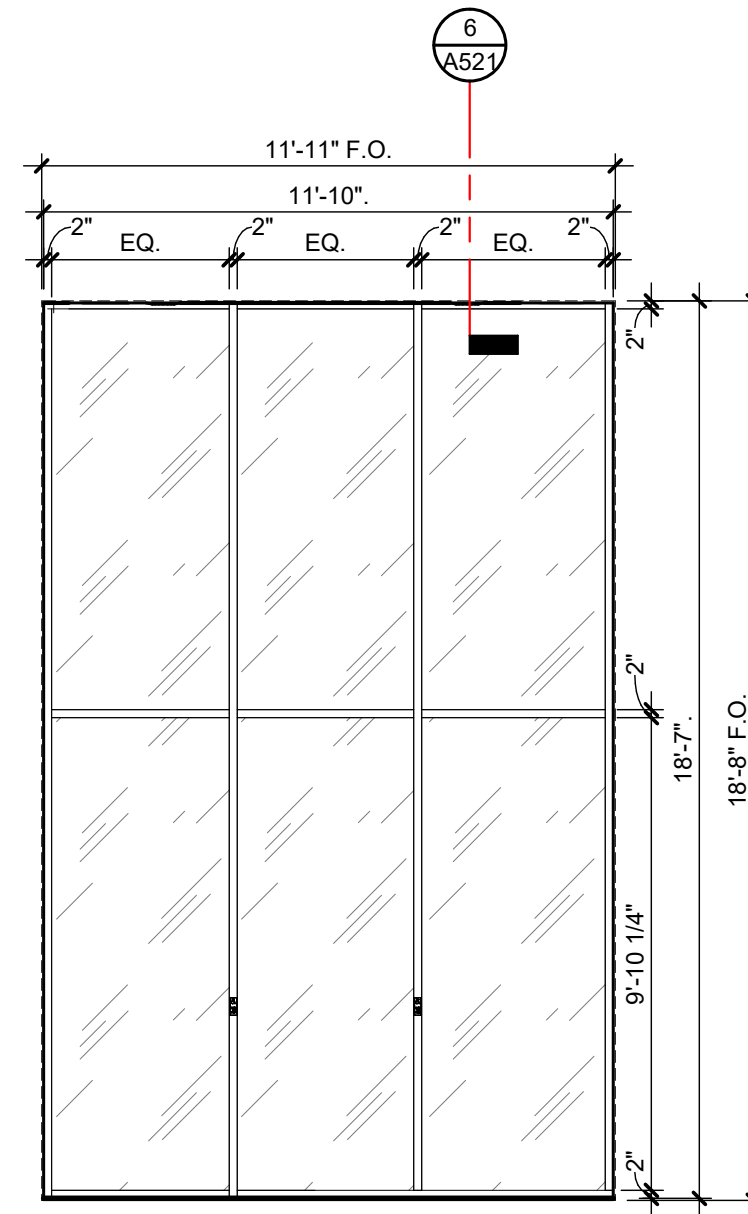

15 SF-B9 INTERIOR
SCALE: 1/4" = 1'-0"

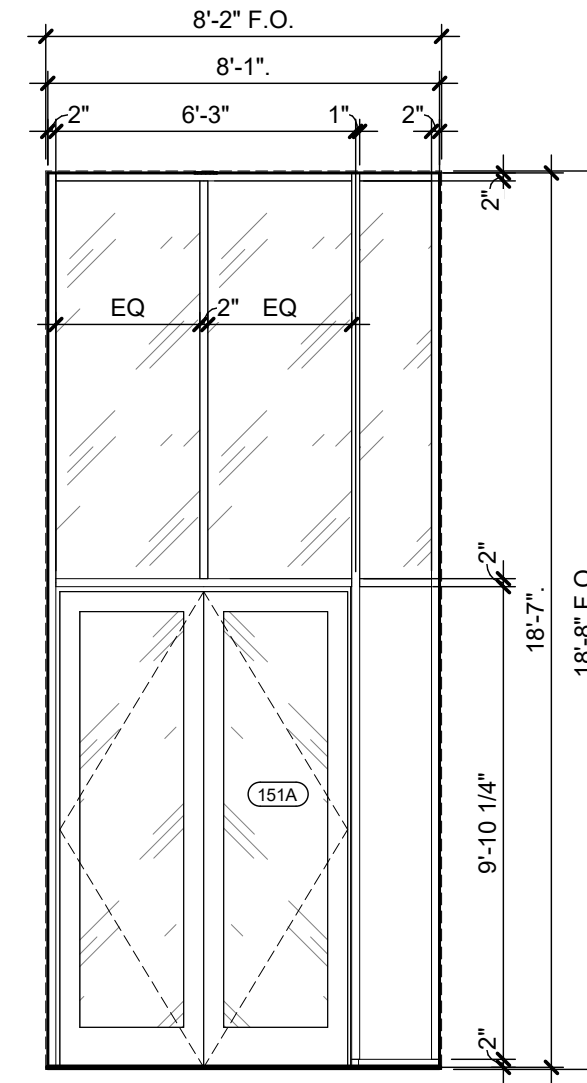

14 SF-B8 INTERIOR
SCALE: 1/4" = 1'-0"

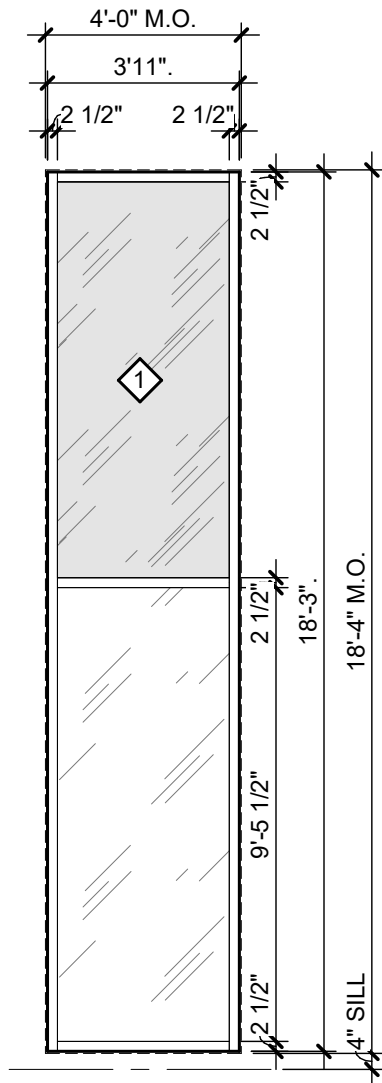

13 CW-B6 CURTAIN WALL
SCALE: 1/4" = 1'-0"

Van Buren Charter Township

Van Buren Township, MI

The Lakeside Park

REVISIONS		
10/27/2026	A2	ADDENDUM NO. 2

10/12/2026	BIDS & PERMIT
09/21/2026	CD PEER REVIEW
08/09/2026	CD TEAM REVIEW
08/10/2026	CD 50% PROGRESS
08/22/2026	DD OWNER REVIEW
06/15/2026	DD PEER REVIEW
06/08/2026	DD 90% PROGRESS
05/18/2026	DD 90% PROGRESS
02/23/2026	SD OWNER REVIEW
02/13/2026	SD PEER REVIEW
02/09/2026	SD PROGRESS REVIEW

Drawn By IOLKHOVESKA
Designer IELHENNAWAY
Reviewer WLAPSON
Manager CKRETOVIC






Hard copy is intended to be 24"x36" when plotted. Scale(s) indicated and graphic quality may not be accurate for any other size.

PROJECT NO.
2500281

SHEET NO.

A204

©Copyright 2026
All Rights Reserved

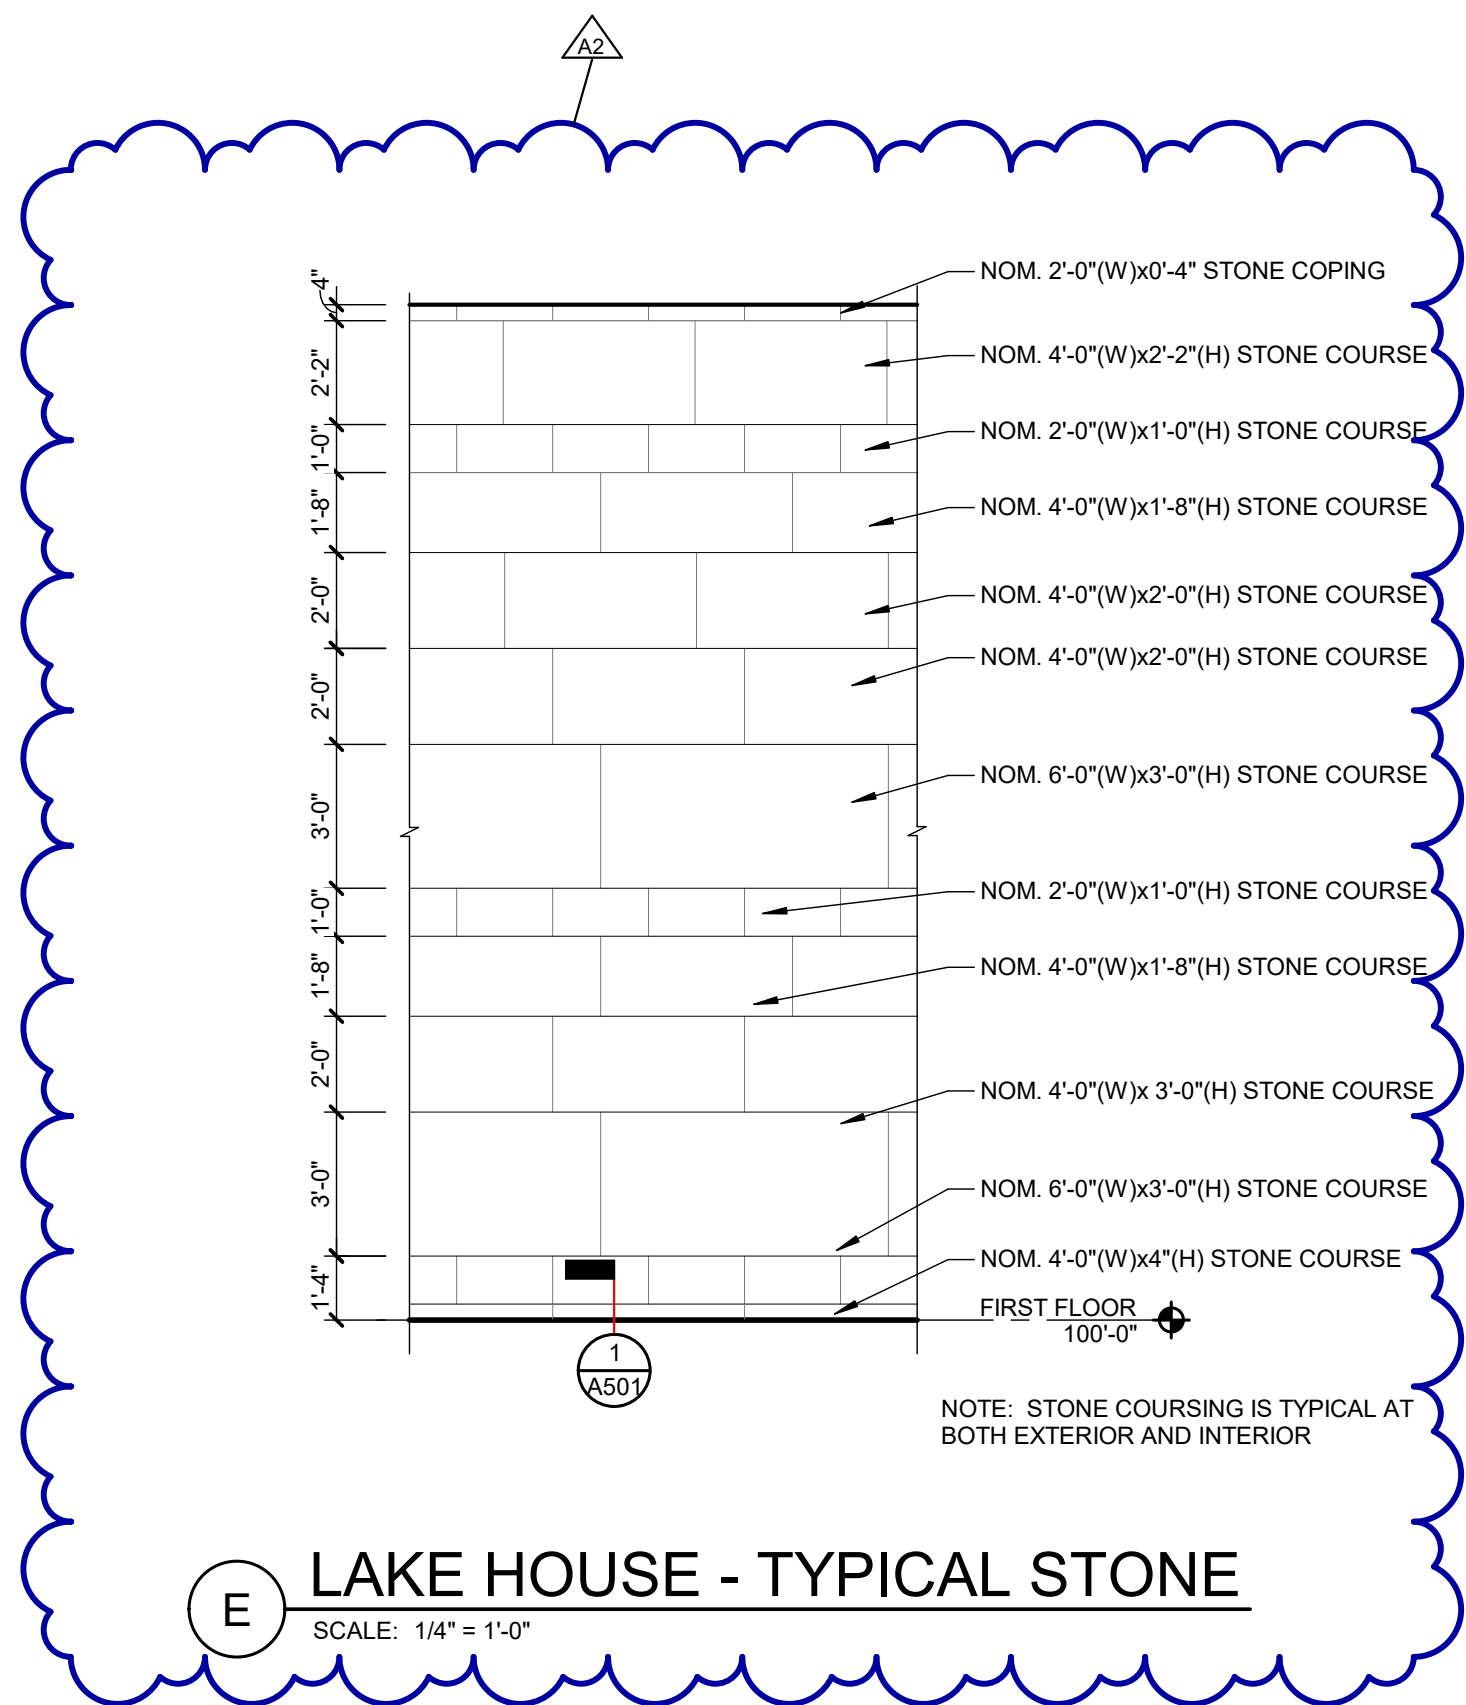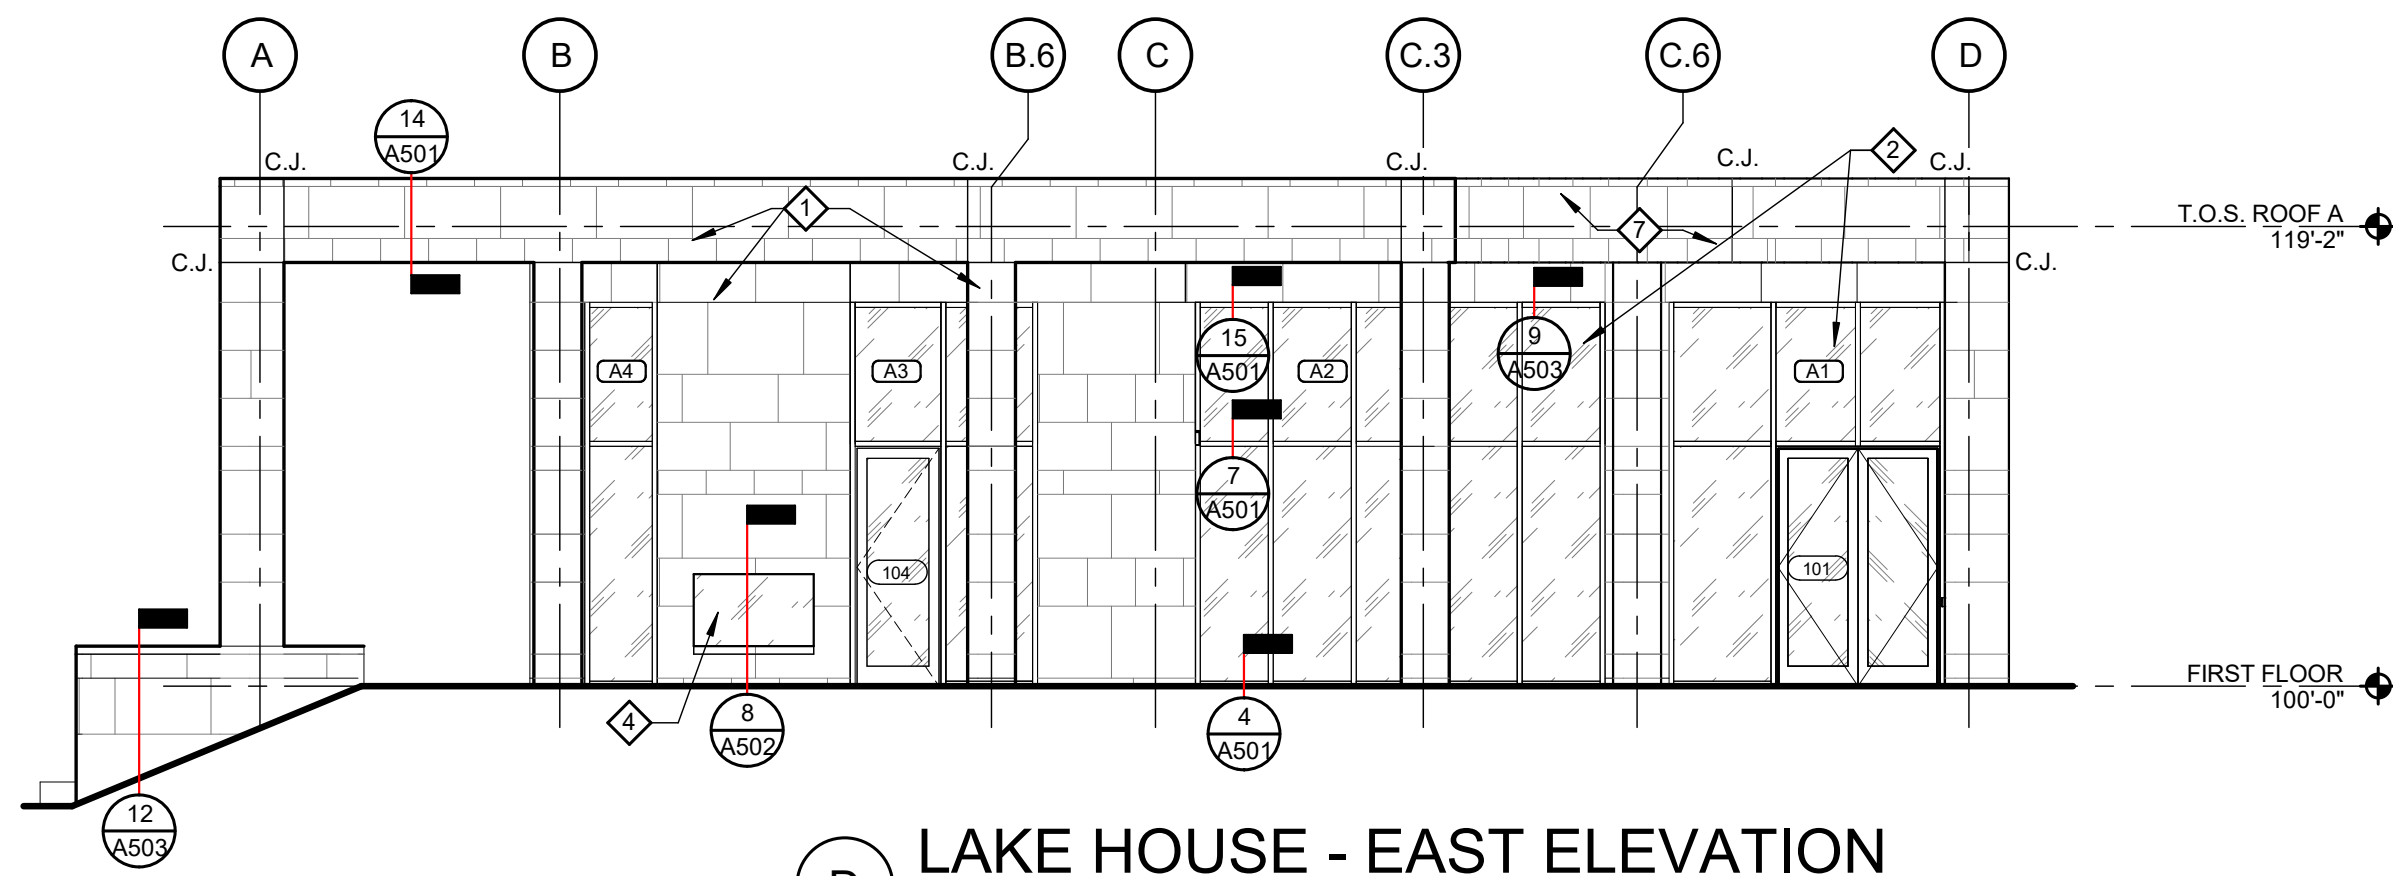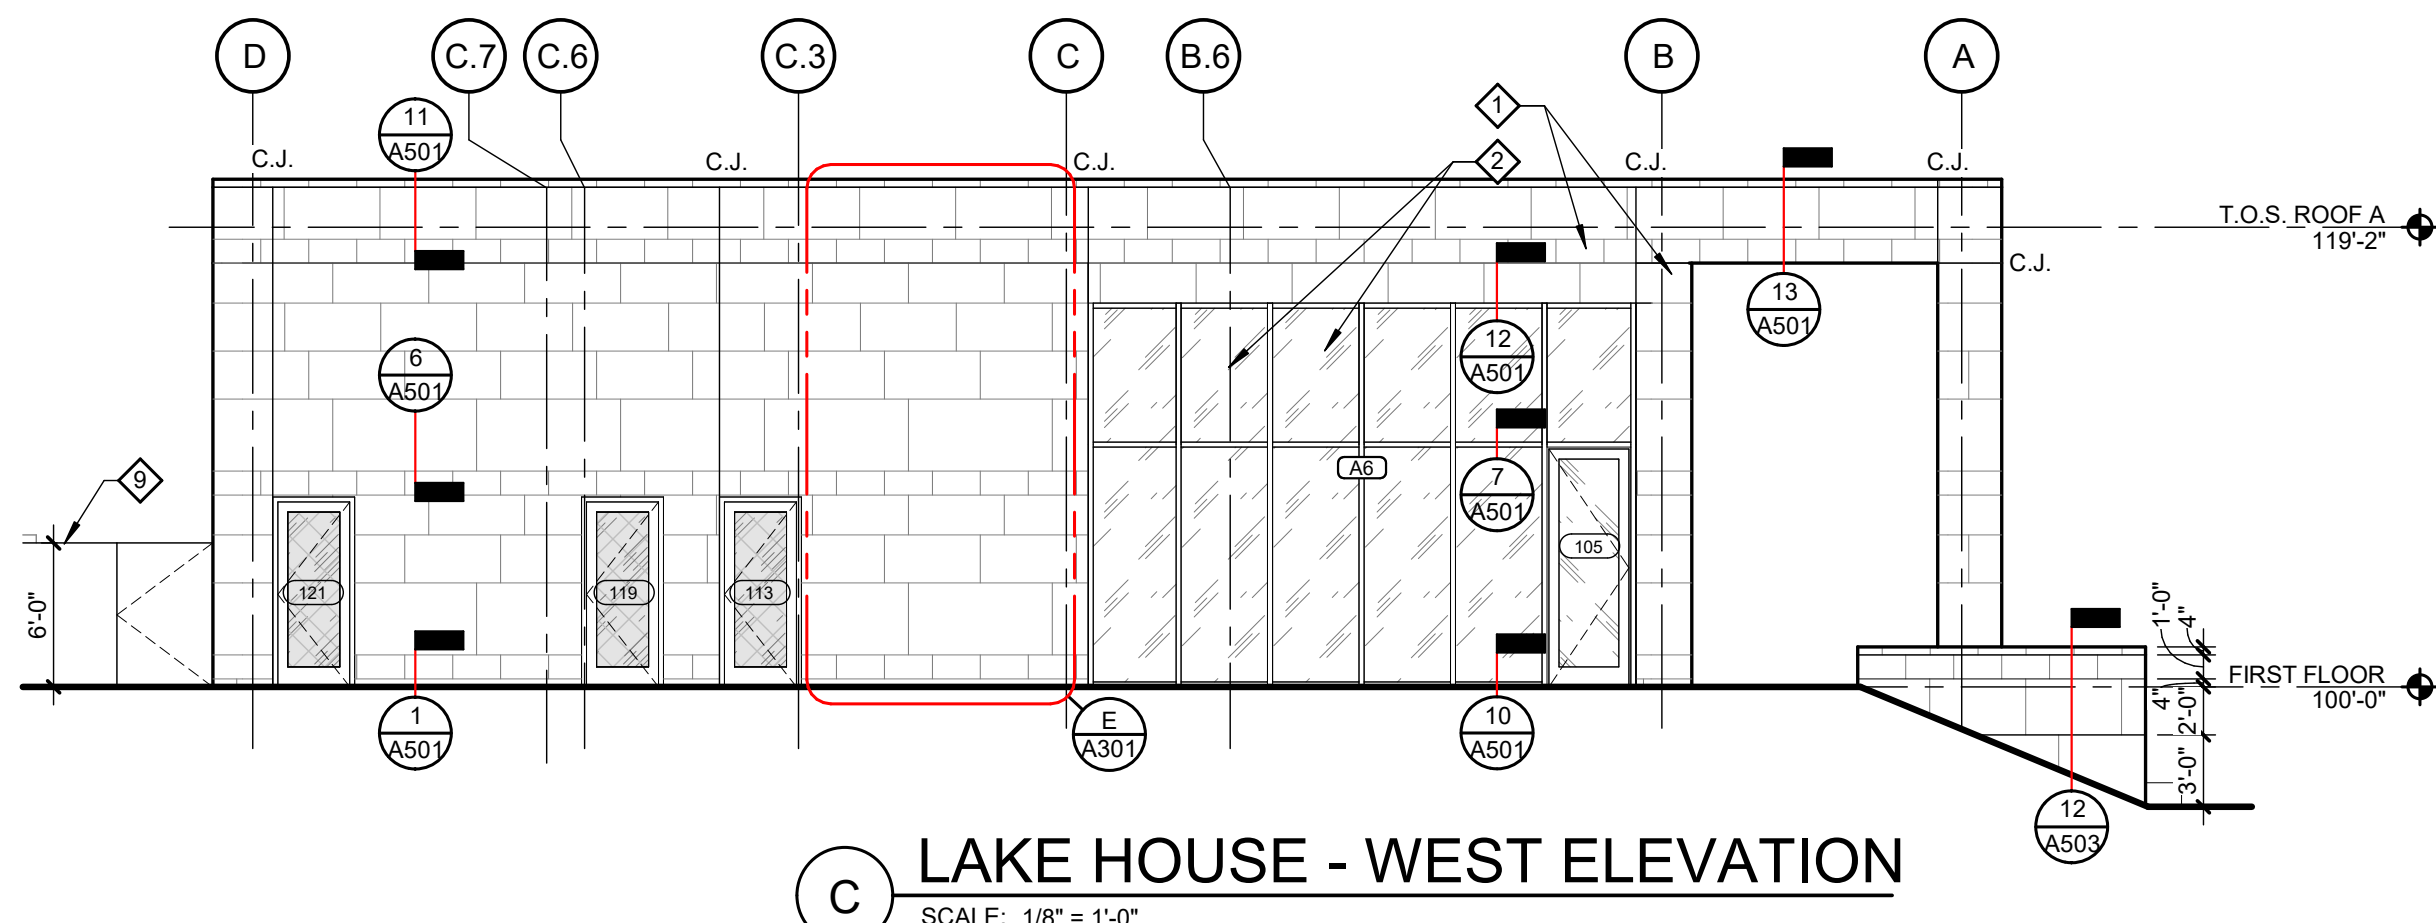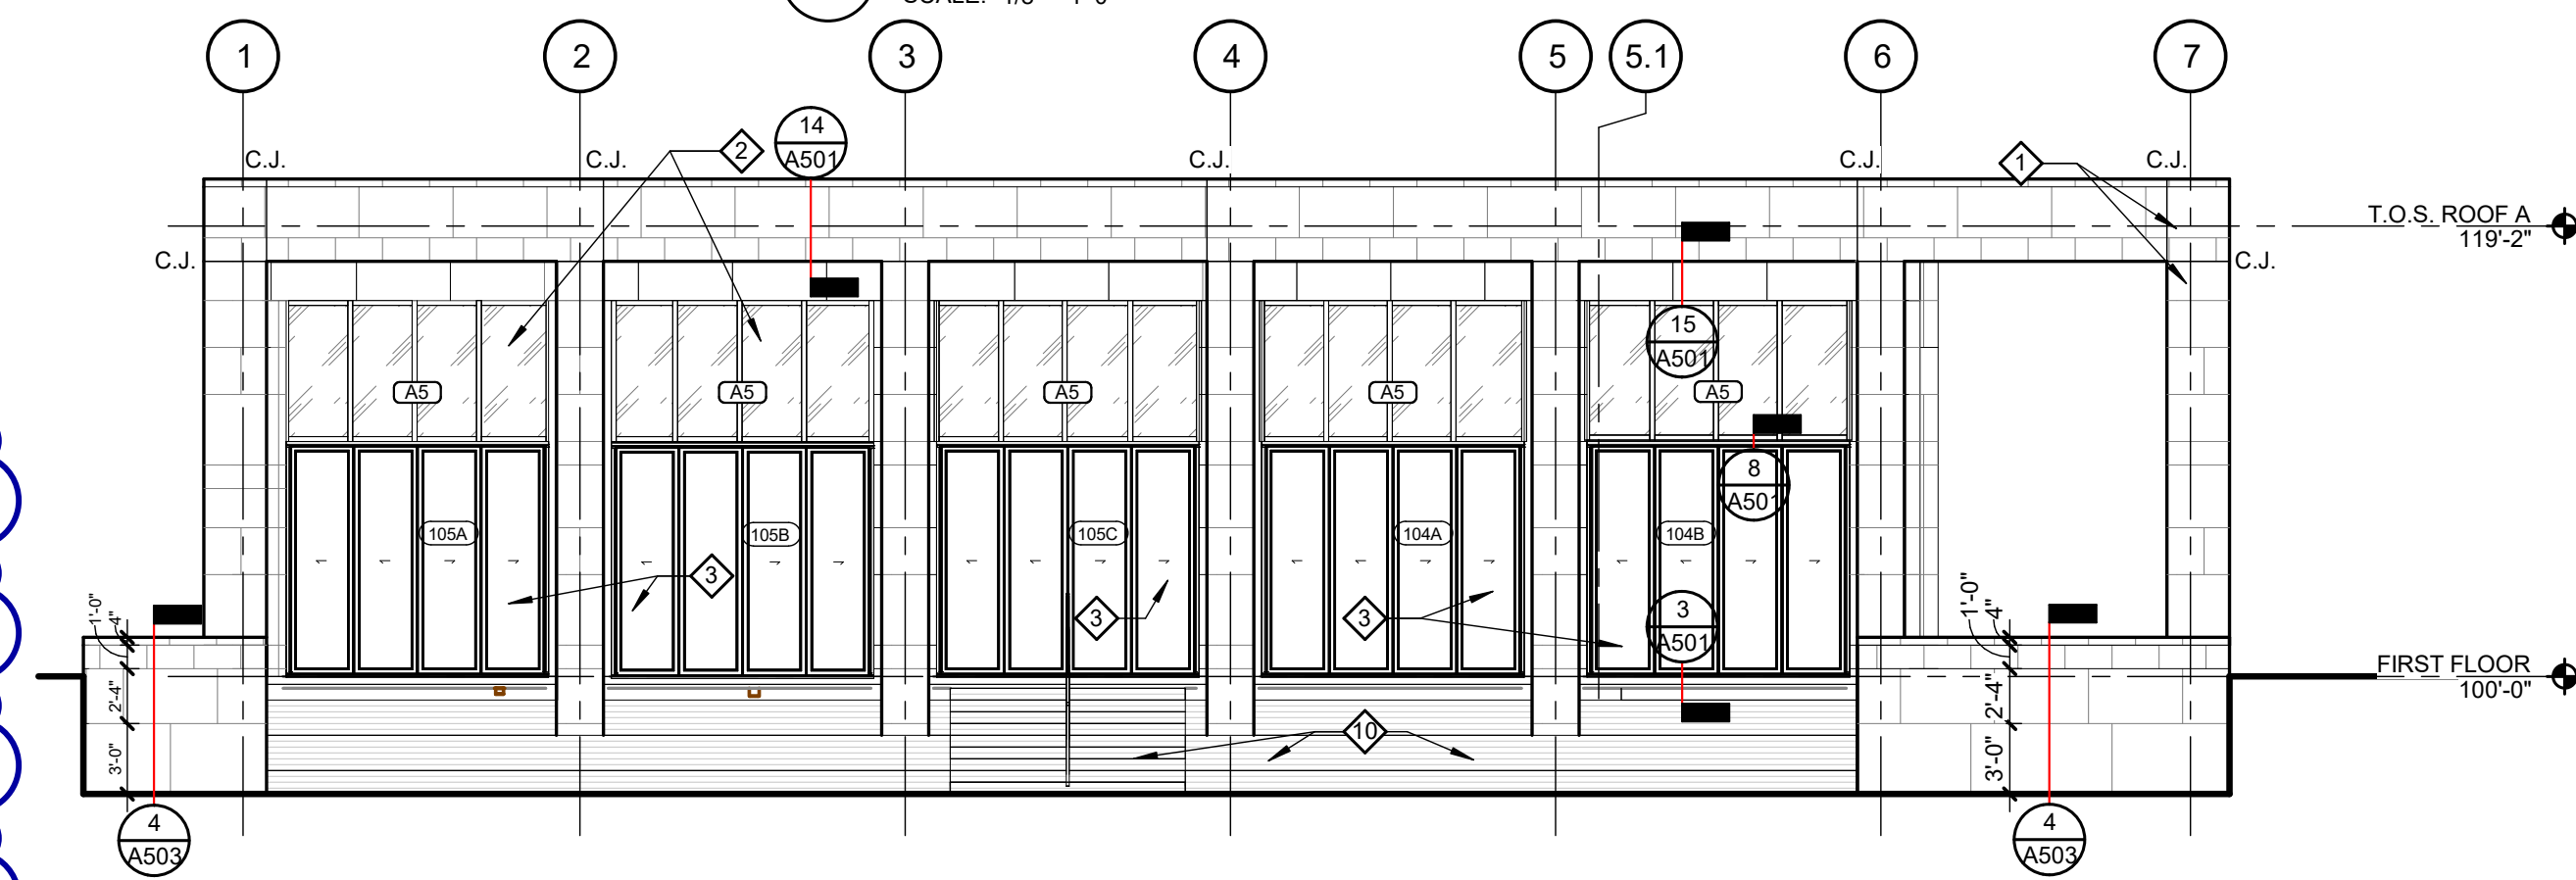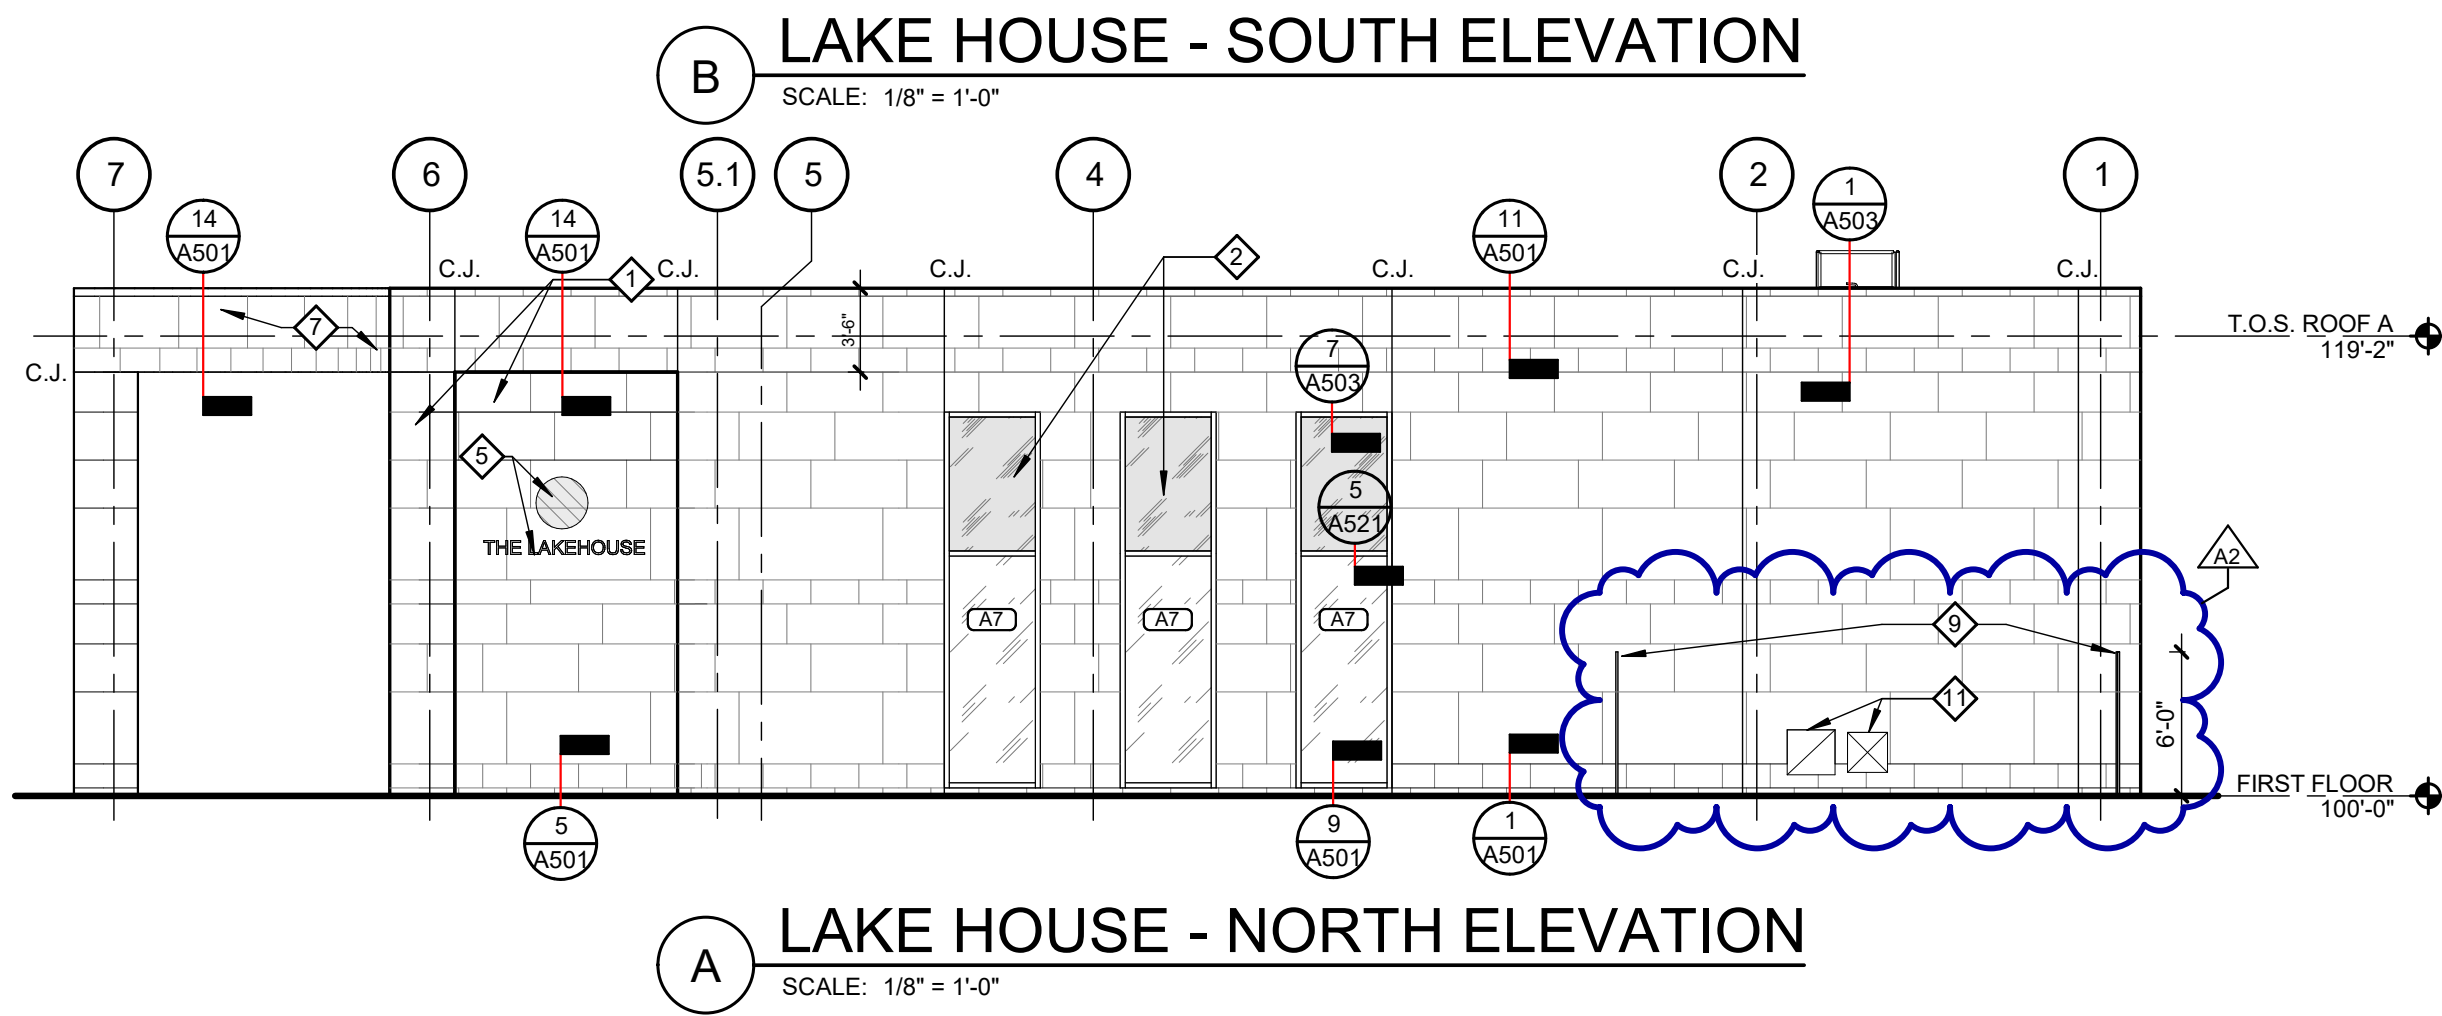

- KEY NOTES**
- NATURAL STONE VENEER, TYP.
 - ALUMINUM CURTAIN WALL, TYP.
 - FOLDING WALL
 - FIREPLACE; DOUBLE-SIDED GLASS FRONT; APPROX 5'W X 3'H
 - SIGNAGE
 - NATURAL STONE COPING TYP.
 - FACETED STONE WALL WITH SURFACE CUT TO RADIUS, REFER TO ROOF PLAN FOR DIMENSIONS
 - DASHED LINE INDICATES SKY RING STRUCTURE BY OTHERS, REFER TO MANUFACTURER DRAWINGS
 - PERFORATED METAL MECHANICAL SCREEN WALLS, ALIGN W/ LIMESTONE COURSING
 - TIERED SEATING AND STAIRS, REFER TO CIVIL DRAWINGS FOR DETAIL
 - THRU-WALL MECHANICAL VENTS, REFER TO MECHANICAL FOR SIZE AND LOCATION

Van Buren Charter Township
Van Buren Township, MI
The Lakeside Park

REVISIONS		
10/27/2026	A2	ADDENDUM NO. 2


10/12/2026	BIDS & PERMIT
09/21/2026	CD PEER REVIEW
09/09/2026	CD TEAM REVIEW
08/10/2026	CD 50% PROGRESS
08/22/2026	DD OWNER REVIEW
06/15/2026	DD PEER REVIEW
06/08/2026	DD 90 % PROGRESS
05/18/2026	DD 50 % PROGRESS
02/23/2026	SD OWNER REVIEW
02/13/2026	SD PEER REVIEW
02/09/2026	SD PROGRESS REVIEW

Drawn By IOLKHOVESKA
Designer IELHENNAWY
Reviewer WLRAPSON
Manager CKRETOVIC


Hard copy is intended to be 24"x36" when plotted. Scale(s) indicated and graphic quality may not be accurate for any other size.

PROJECT NO.
2500281
SHEET NO.


A301

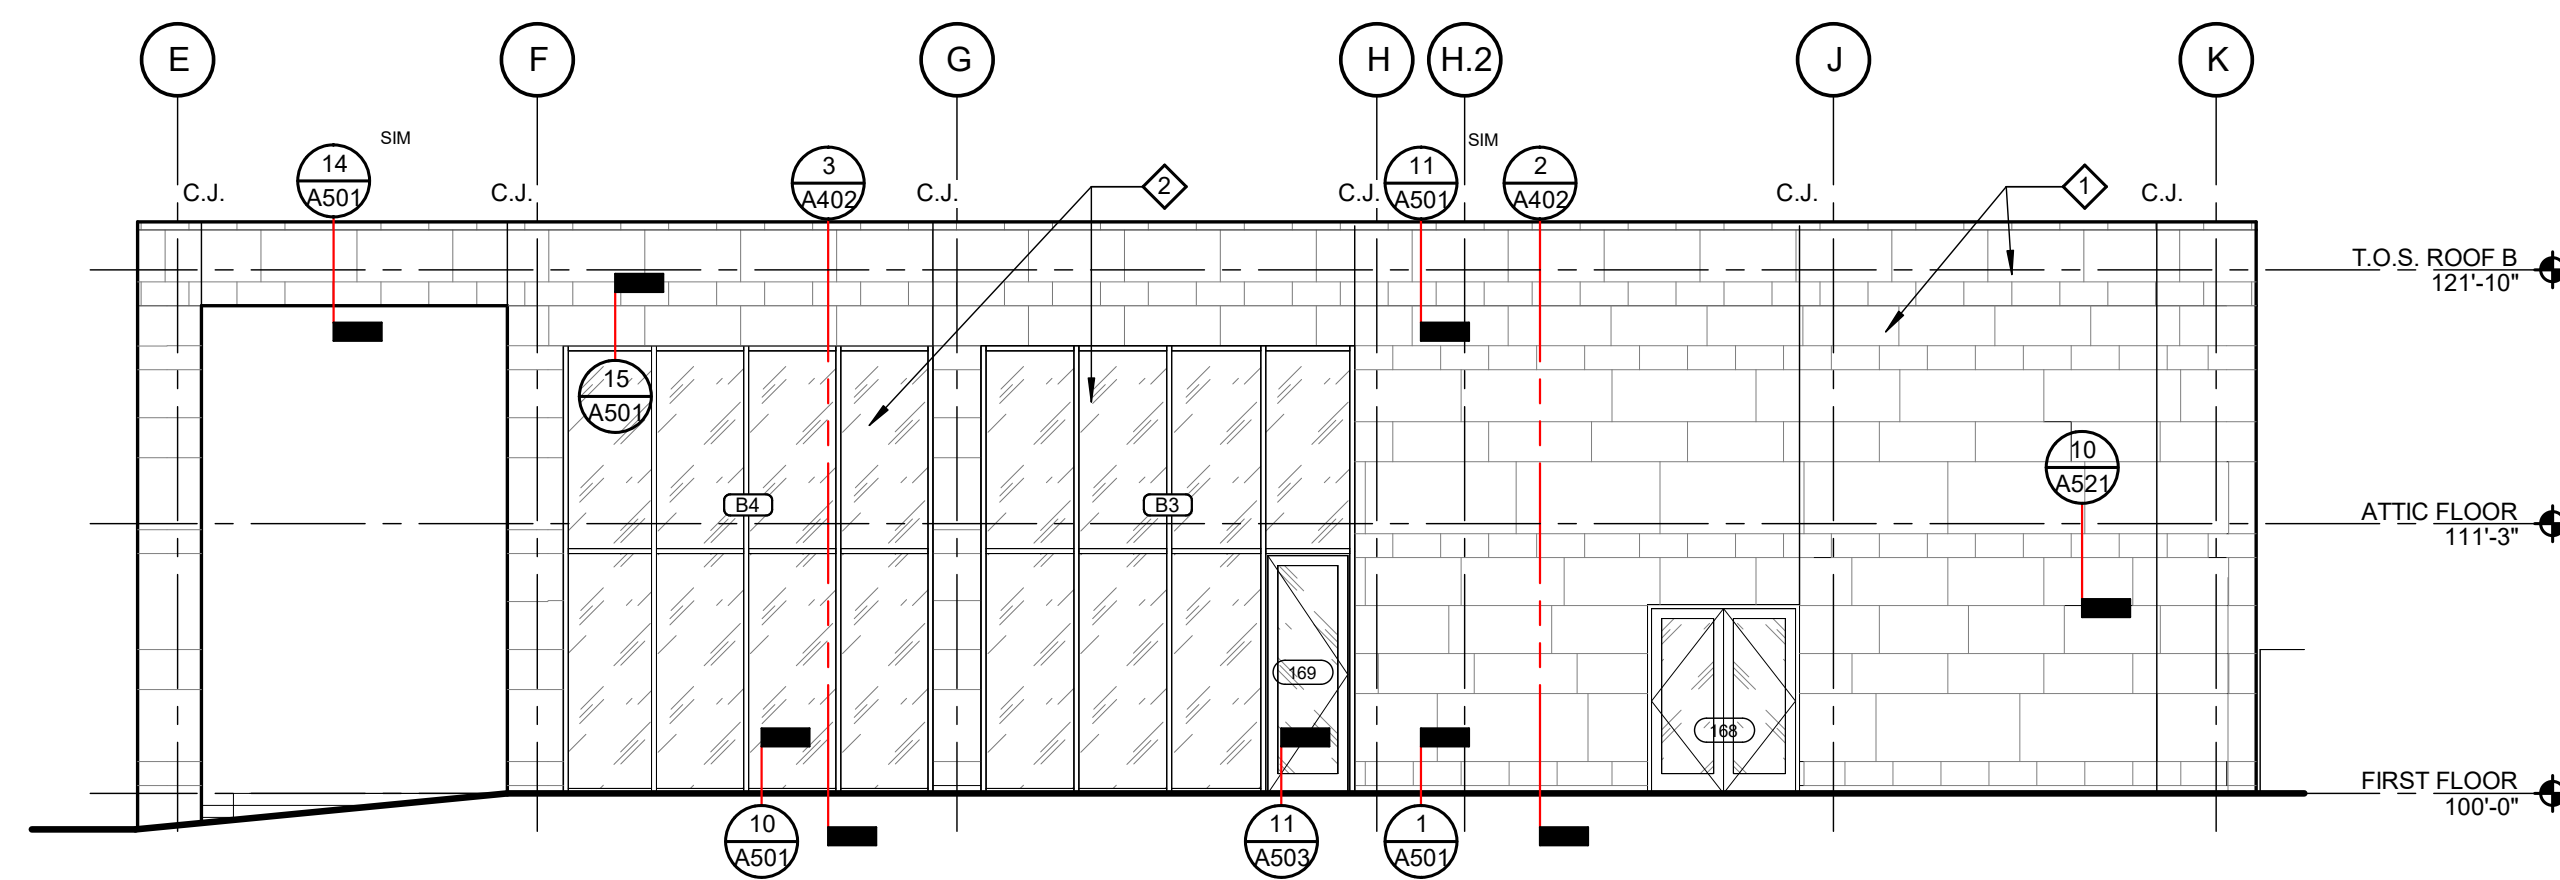


LAKE HALL - EAST ELEVATION
SCALE: 1/8" = 1'-0"

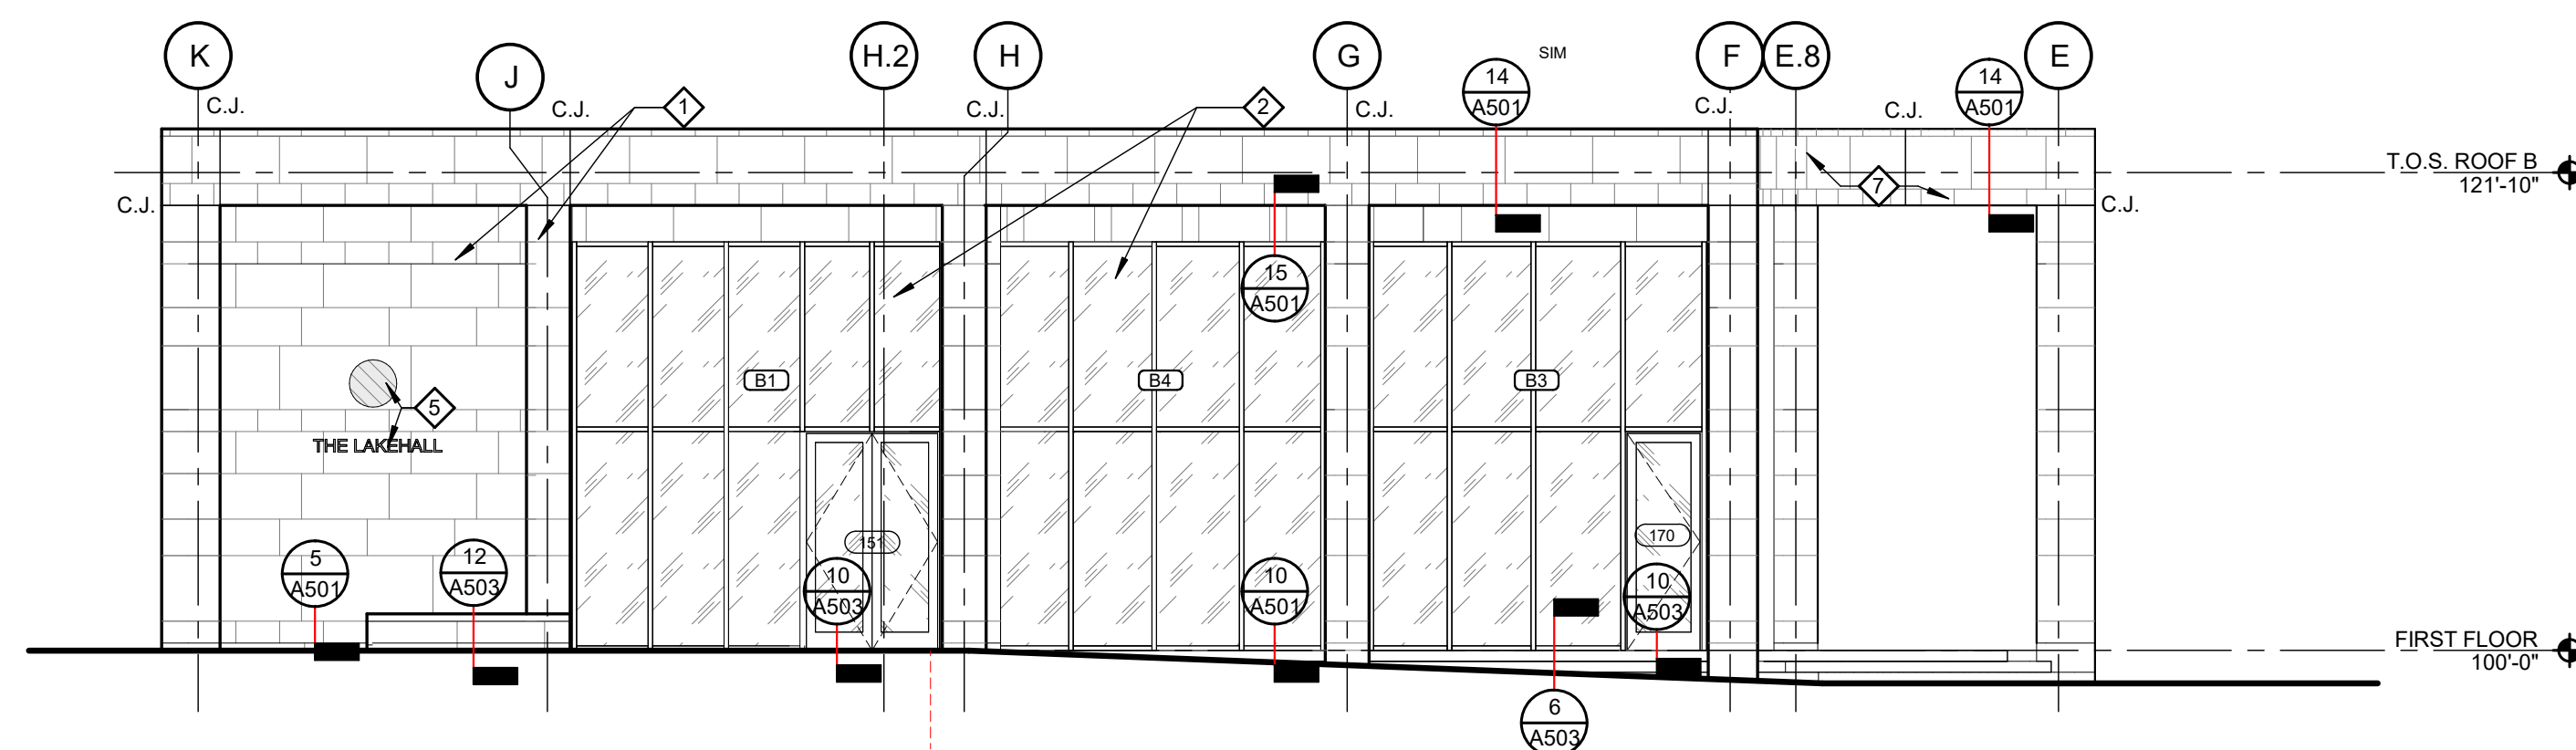


C LAKE HALL - WEST ELEVATION
SCALE: 1/8" = 1'-0"

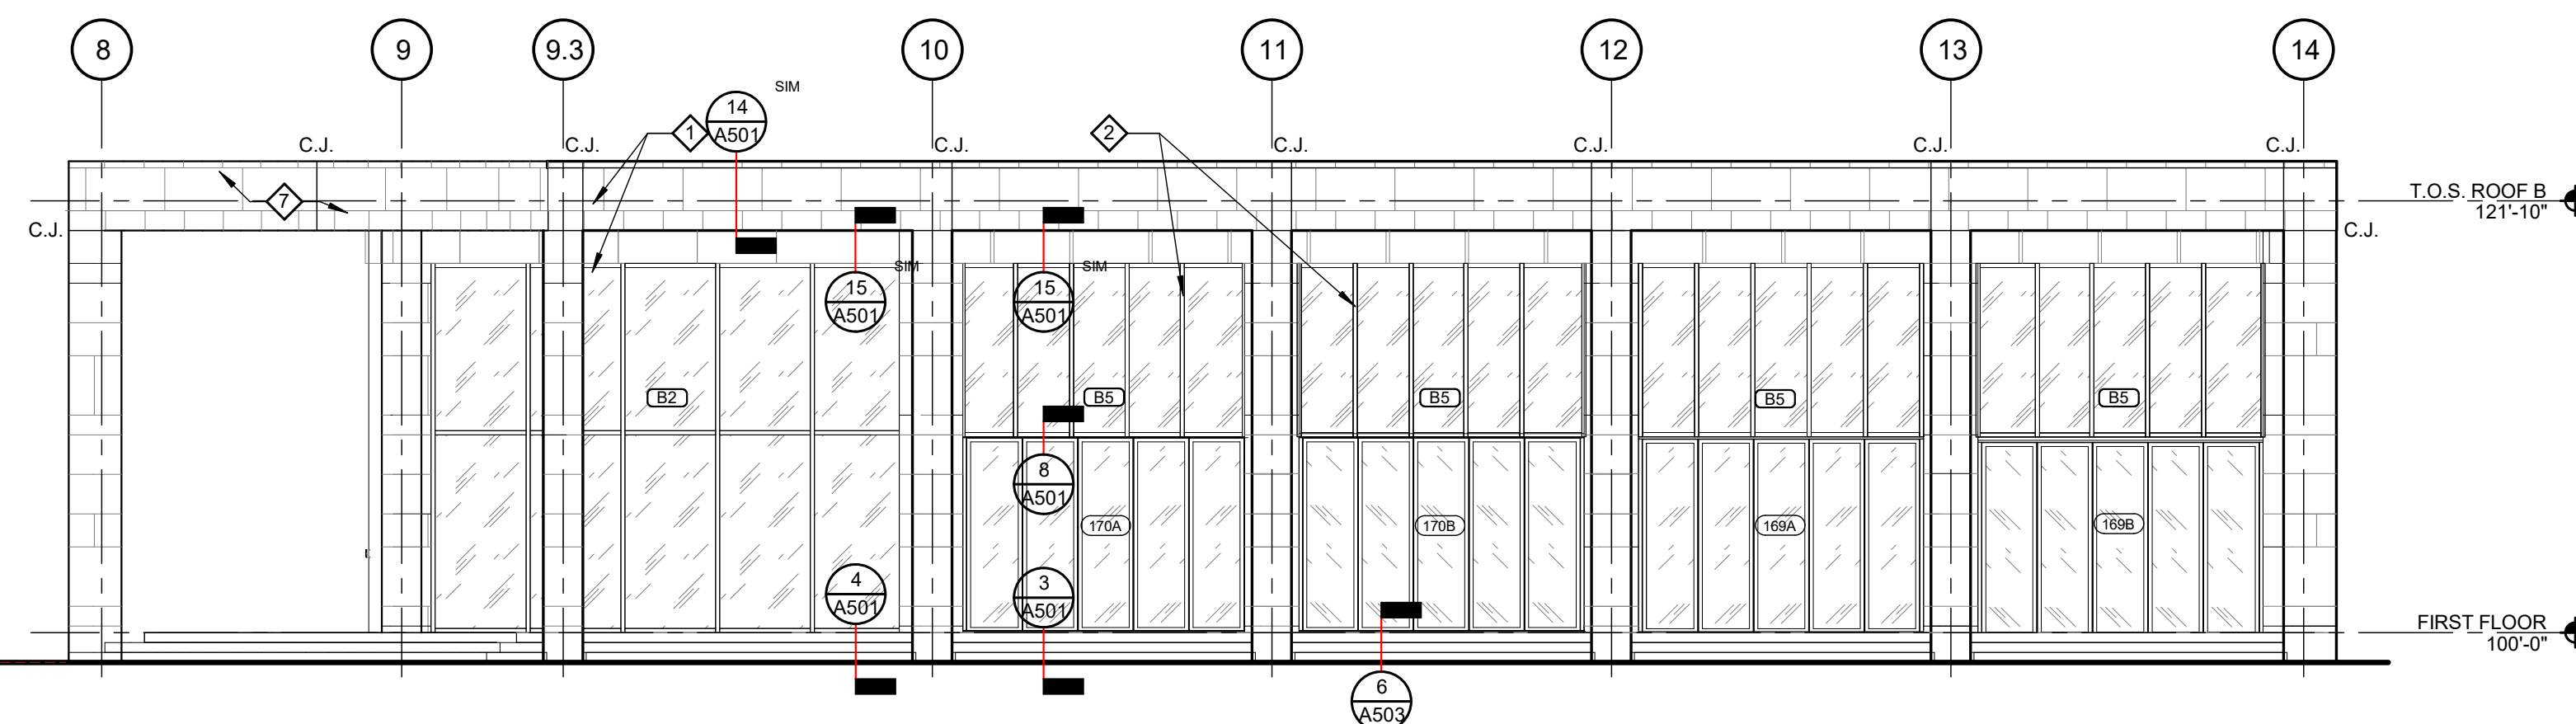

B LAKE HALL - SOUTH ELEVATION
SCALE: 1/8" = 1'-0"

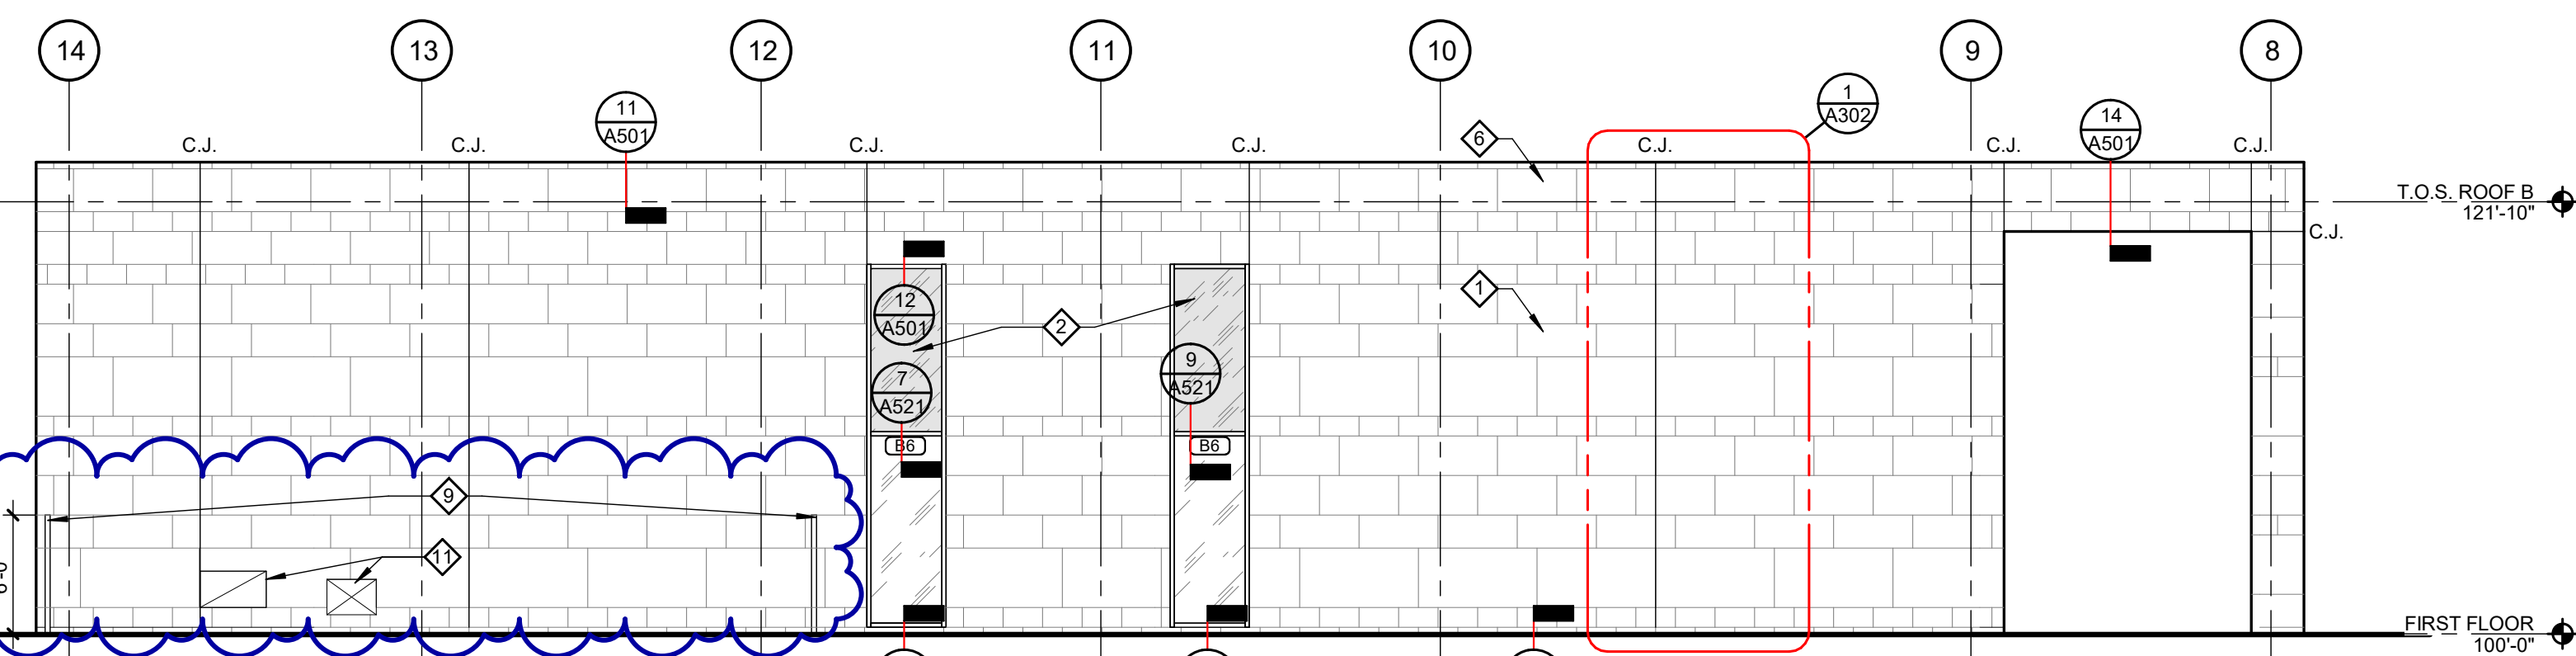

LAKE HALL - NORTH ELEVATION
SCALE: 1/8" = 1'-0"

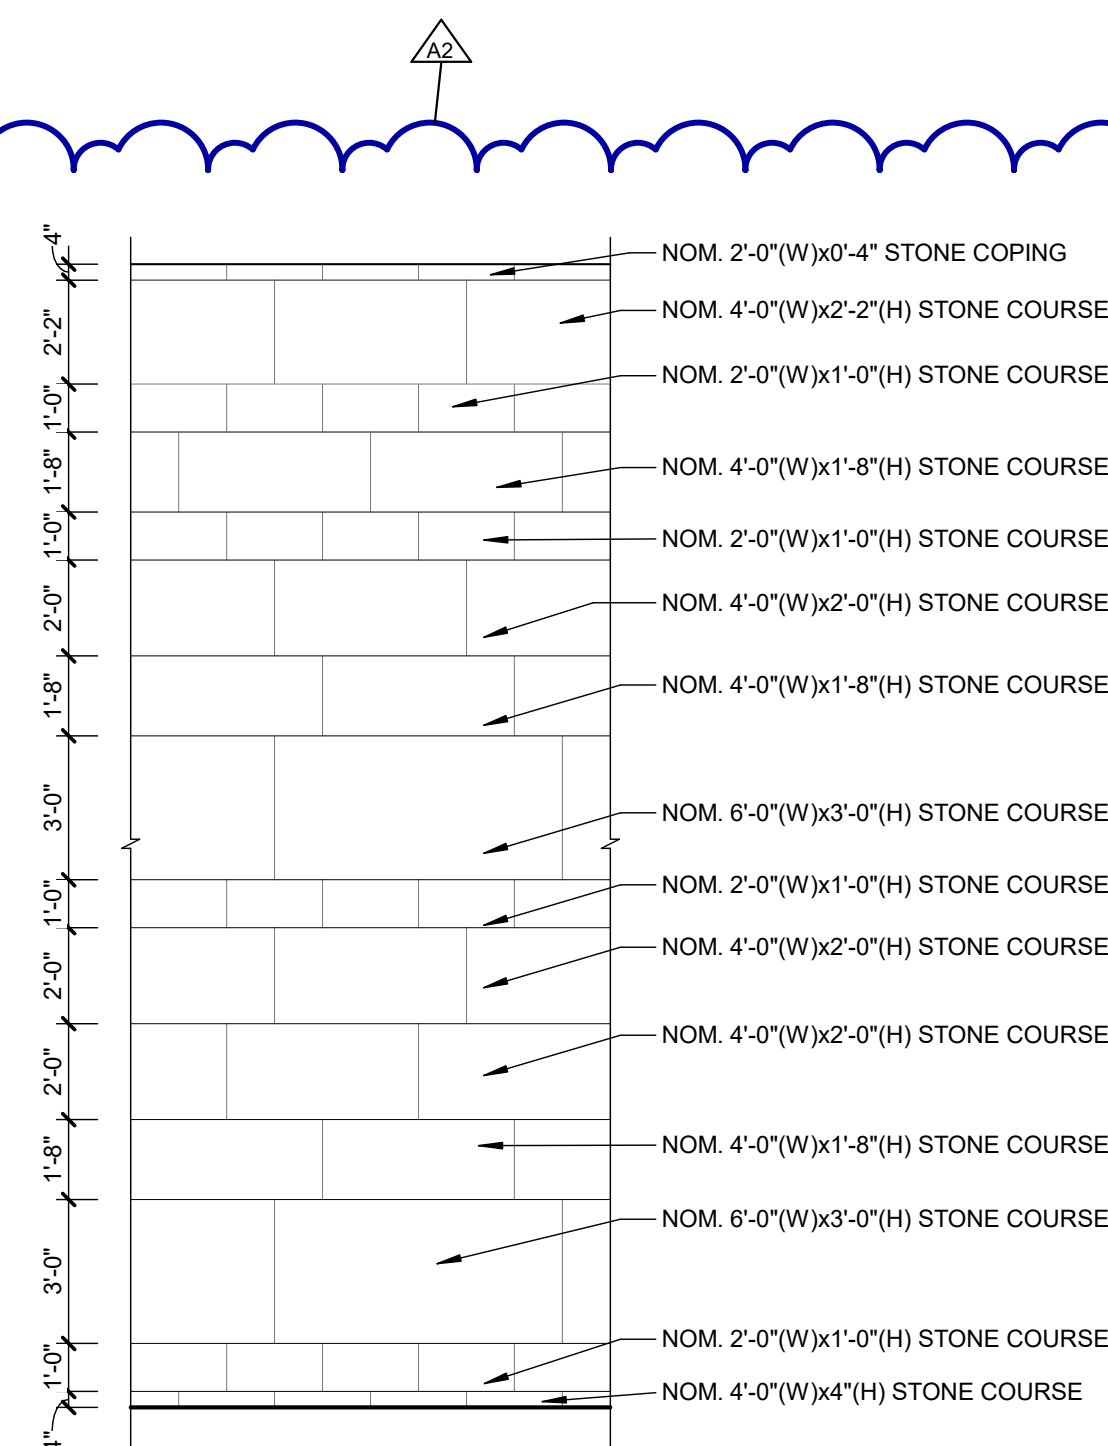

1 LAKE HALL - TYPICAL STONE
SCALE: 1/4" = 1'-0"

- 

KEY NOTES

1

NATURAL STONE VENEER, TYP.

2

ALUMINUM CURTAIN WALL, TYP.

3

FOLDING WALL

4

FIREPLACE; DOUBLE-SIDED GLASS FRONT; APPROX 5'W X 3'H

5

SIGNAGE

6

NATURAL STONE COPING TYP.

7

FACETED STONE WALL WITH SURFACE CUT TO RADIUS , REFER TO ROOF PLAN FOR DIMENSIONS

8

DASHED LINE INDICATES SKY RING STRUCTURE BY OTHERS, REFER TO MANUFACTURER DRAWINGS

9

PERFORATED METAL MECHANICAL SCREEN WALLS. ALIGN W/ LIMESTONE COURSING

10

TIERED SEATING AND STAIRS, REFER TO CIVIL DRAWINGS FOR DETAIL

11

THRU-WALL MECHANICAL VENTS; REFER TO MECHANICAL FOR SIZE AND LOCATION

10/12/2026	BIDS & PERMIT
09/21/2026	CD PEER REVIEW
09/09/2026	CD TEAM REVIEW
08/10/2026	CD 50% PROGRESS
06/22/2026	DD OWNER REVIEW
06/15/2026	DD PEER REVIEW
06/08/2026	DD 90 % PROGRESS
05/18/2026	DD 50 % PROGRESS
02/23/2026	SD OWNER REVIEW
02/13/2026	SD PEER REVIEW
02/09/2026	SD PROGRESS REVIEW

Drawn By	IOLKHOVESKA
Designer	IELHENNAWY
Reviewer	WLRAPSON
Manager	CKRETOVIC


Hard copy is intended to be 24"x36" when plotted. Scale(s) indicated and graphic quality may not be accurate for any other size.

PROJECT NO.


2500281

SHEET NO.

A302

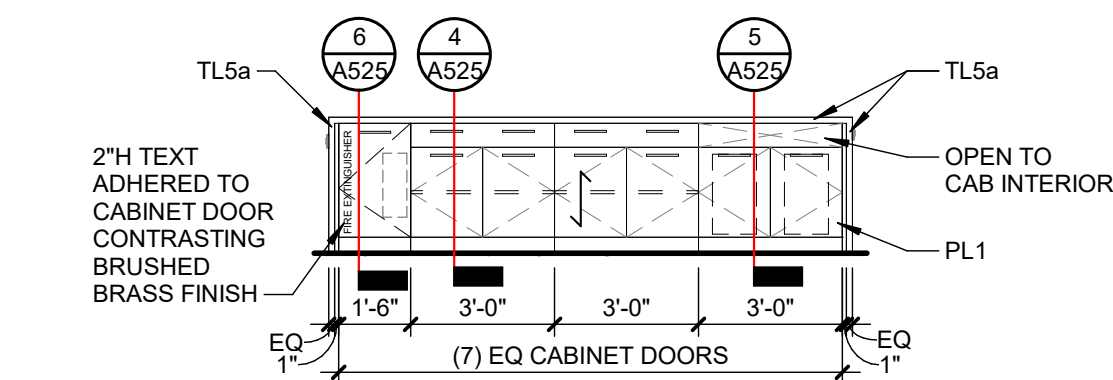

PLOT INFO: 10/27/2026 2:56:23 PM Autodesk Docs://2500281 - Van Buren Twp Lake House/2026_A_2500281.rvt

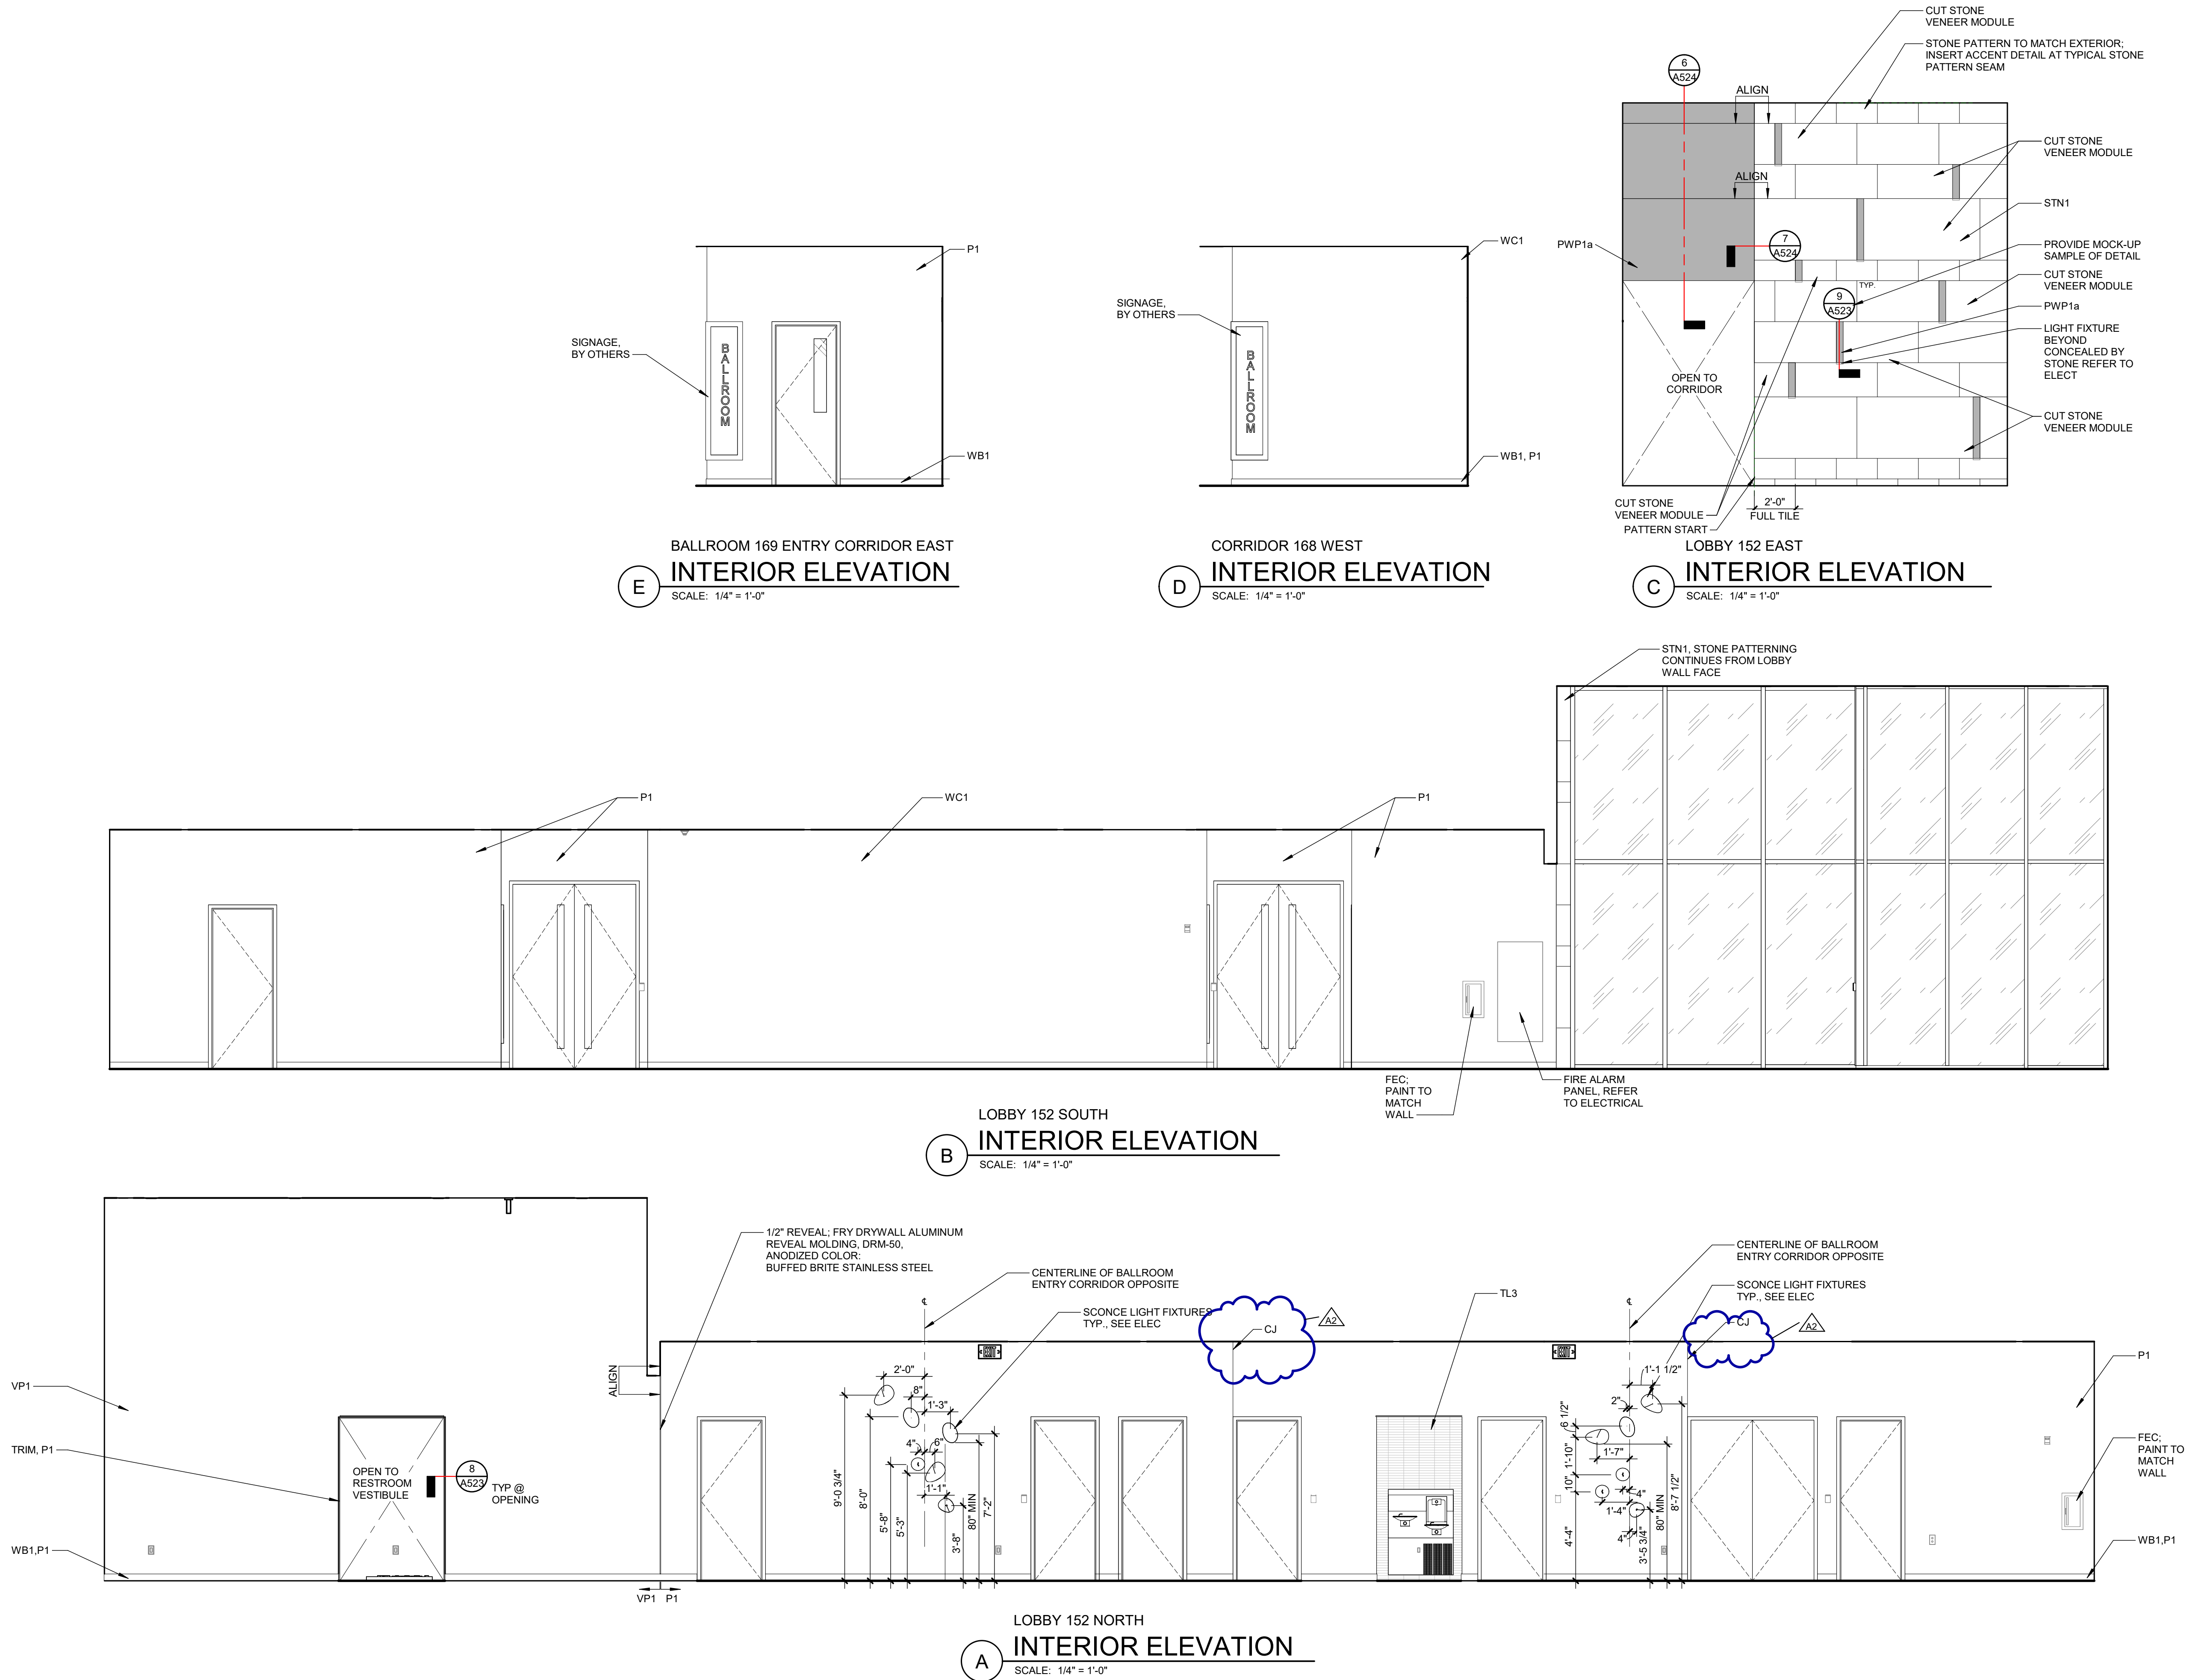

fishbeck
Engineers | Architects | Scientists | Constructors

Van Buren Charter Township
Van Buren Township, MI
The Lakeside Park

REVISIONS		
10/27/2026	A2	ADDENDUM NO. 2

10/12/2026	BIDS & PERMIT
09/21/2026	CD PEER REVIEW
09/09/2026	CD TEAM REVIEW
08/10/2026	CD 50% PROGRESS
08/22/2026	DD OWNER REVIEW
06/15/2026	DD PEER REVIEW
06/08/2026	DD 90 % PROGRESS
05/18/2026	DD 50 % PROGRESS
02/23/2026	SD OWNER REVIEW
02/13/2026	SD PEER REVIEW
02/09/2026	SD PROGRESS REVIEW

Drawn By

Designer

Reviewer

Manager

KBRAUN

KBRAUN

WLRAPSON

CKRETOVIC

Hard copy is intended to be 24"x36" when plotted. Scale(s) indicated and graphic quality may not be accurate for any other size.


PROJECT NO.

2500281


SHEET NO.

A323


©Copyright 2026
All Rights Reserved

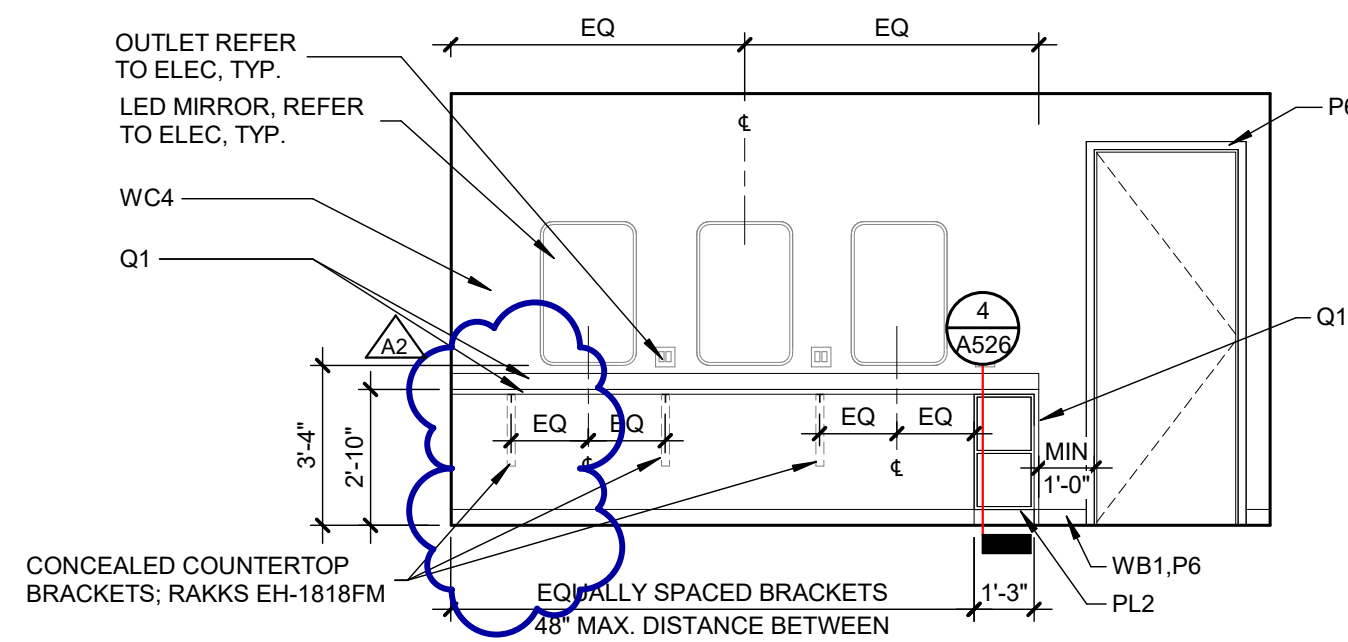


K DRESSING ROOM 156 WEST
INTERIOR ELEVATION
SCALE: 1/4" = 1'-0"

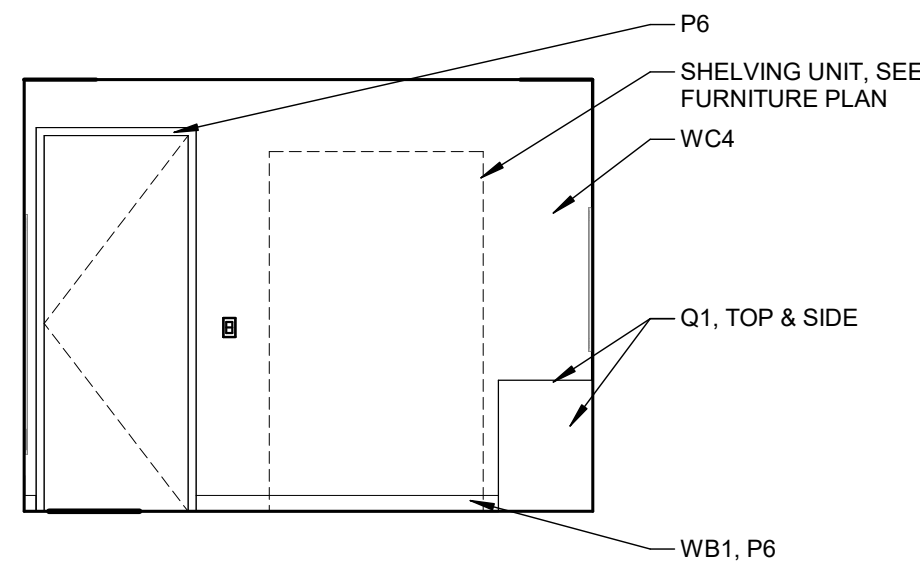


J DRESSING ROOM 156 SOUTH
INTERIOR ELEVATION
SCALE: 1/4" = 1'-0"

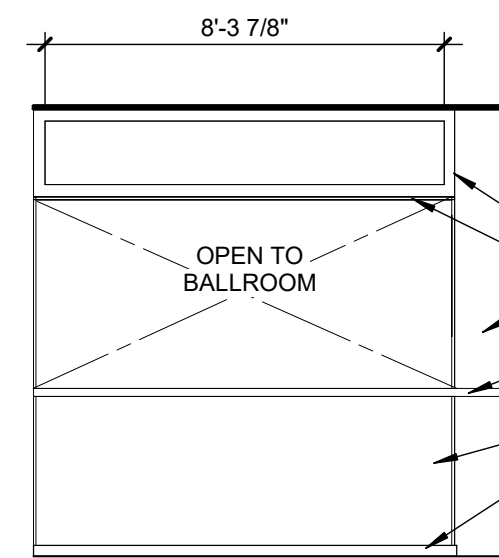


H BAR 165 SOUTH
INTERIOR ELEVATION
SCALE: 1/4" = 1'-0"

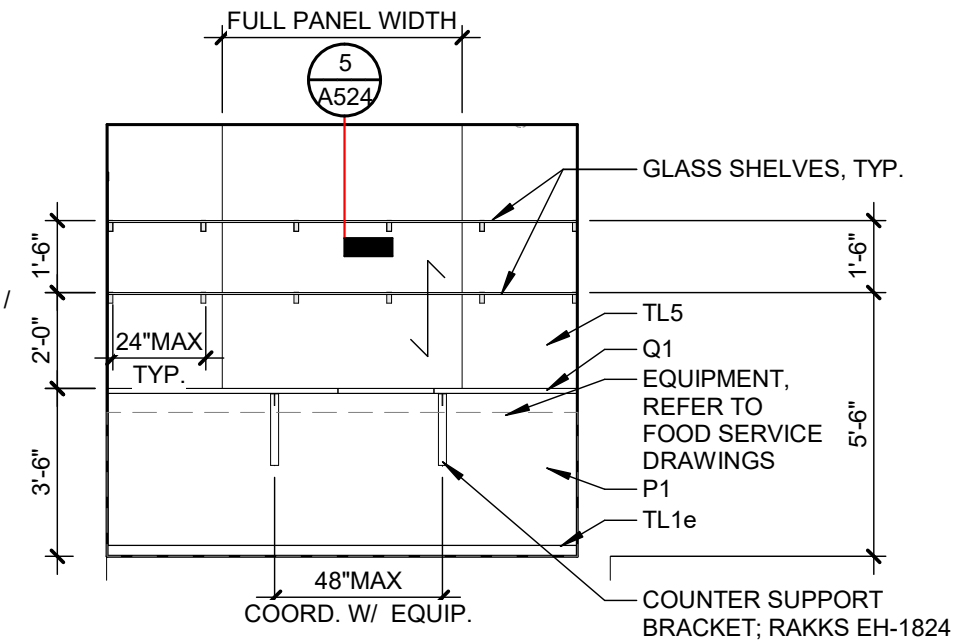


G INTERIOR ELEVATION
SCALE: 1/4" = 1'-0"

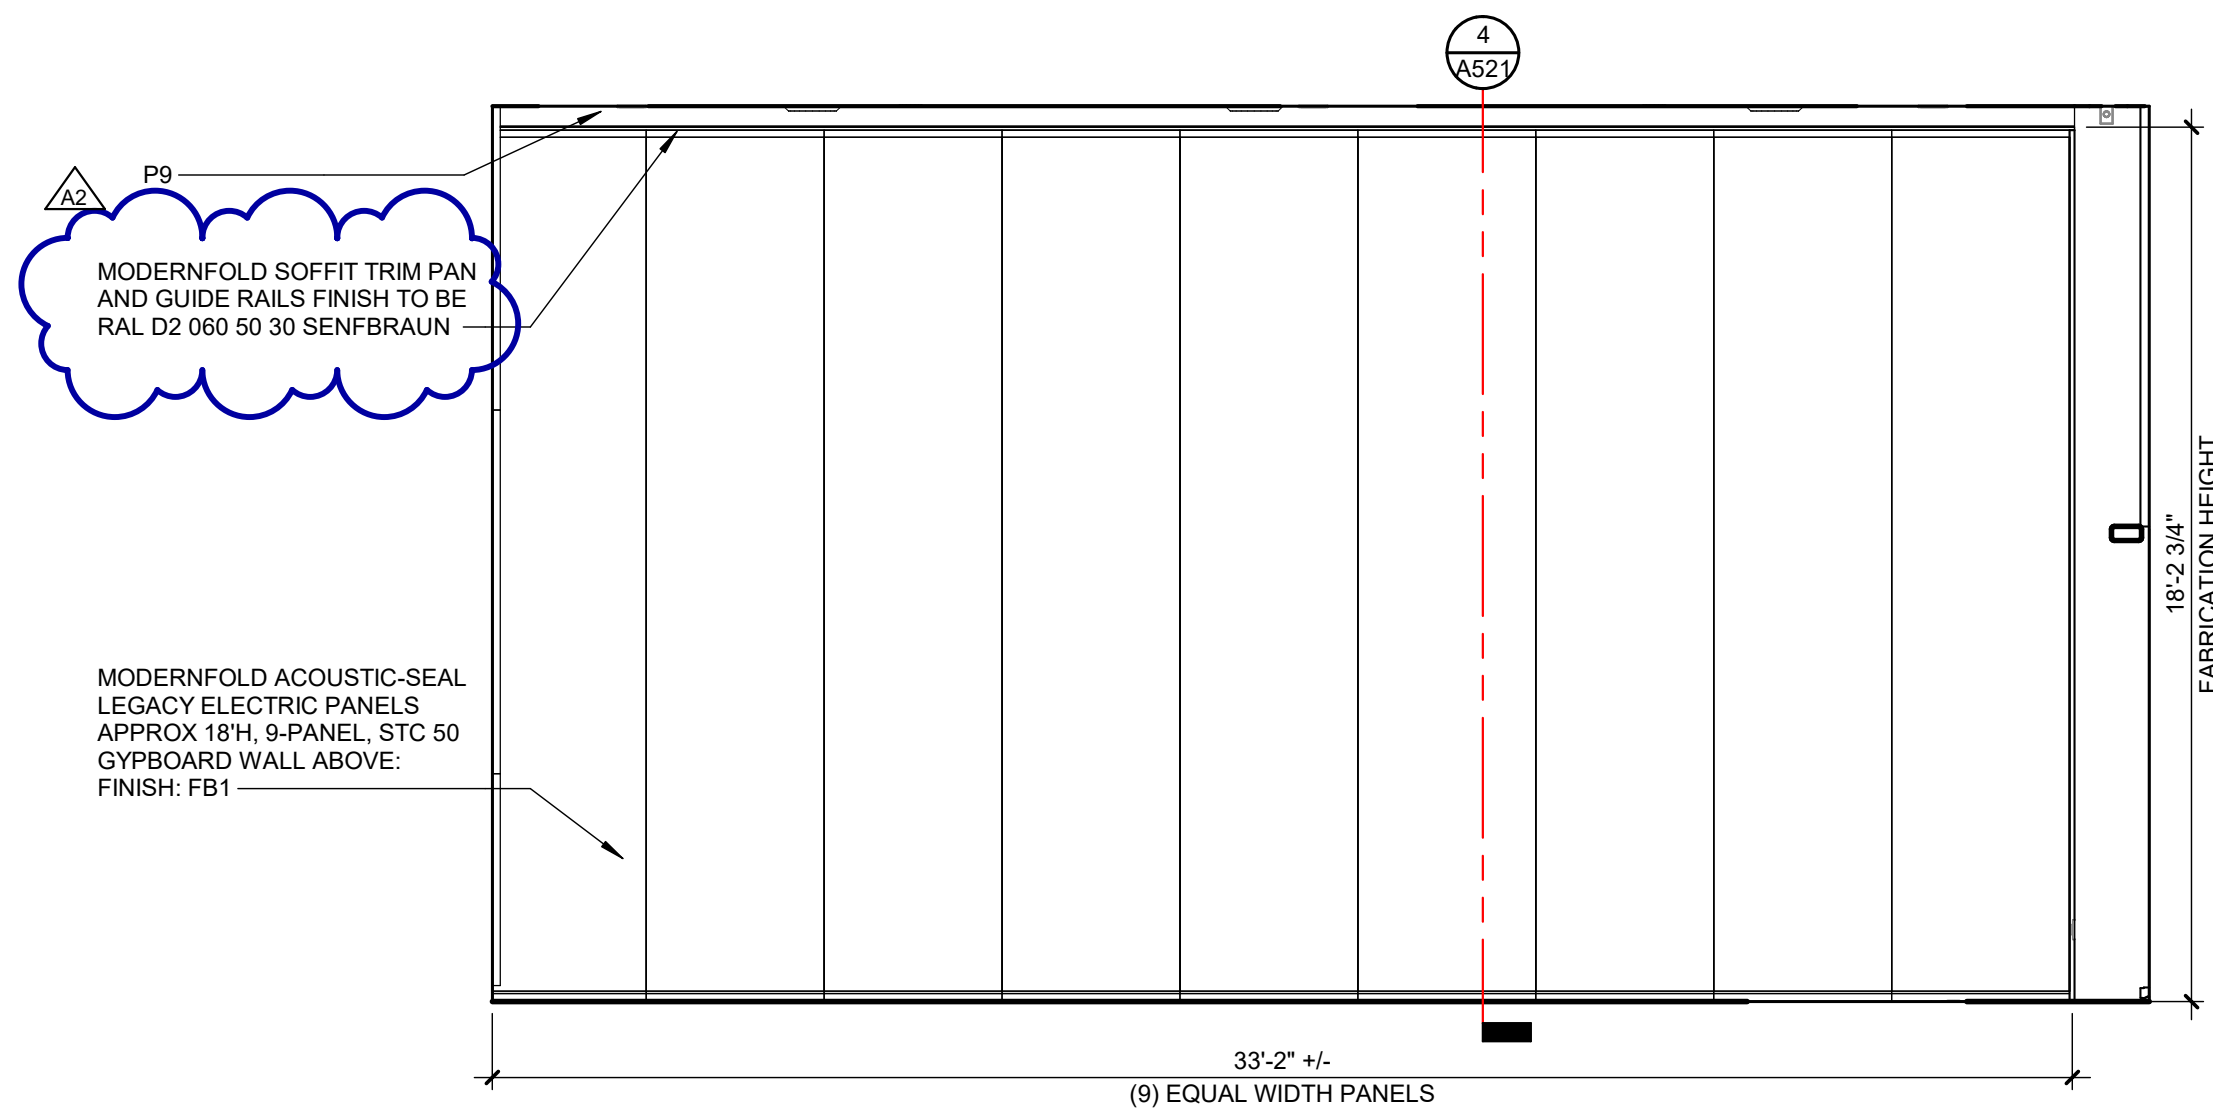


D BALLROOM 170 EAST
INTERIOR ELEVATION
SCALE: 1/4" = 1'-0"

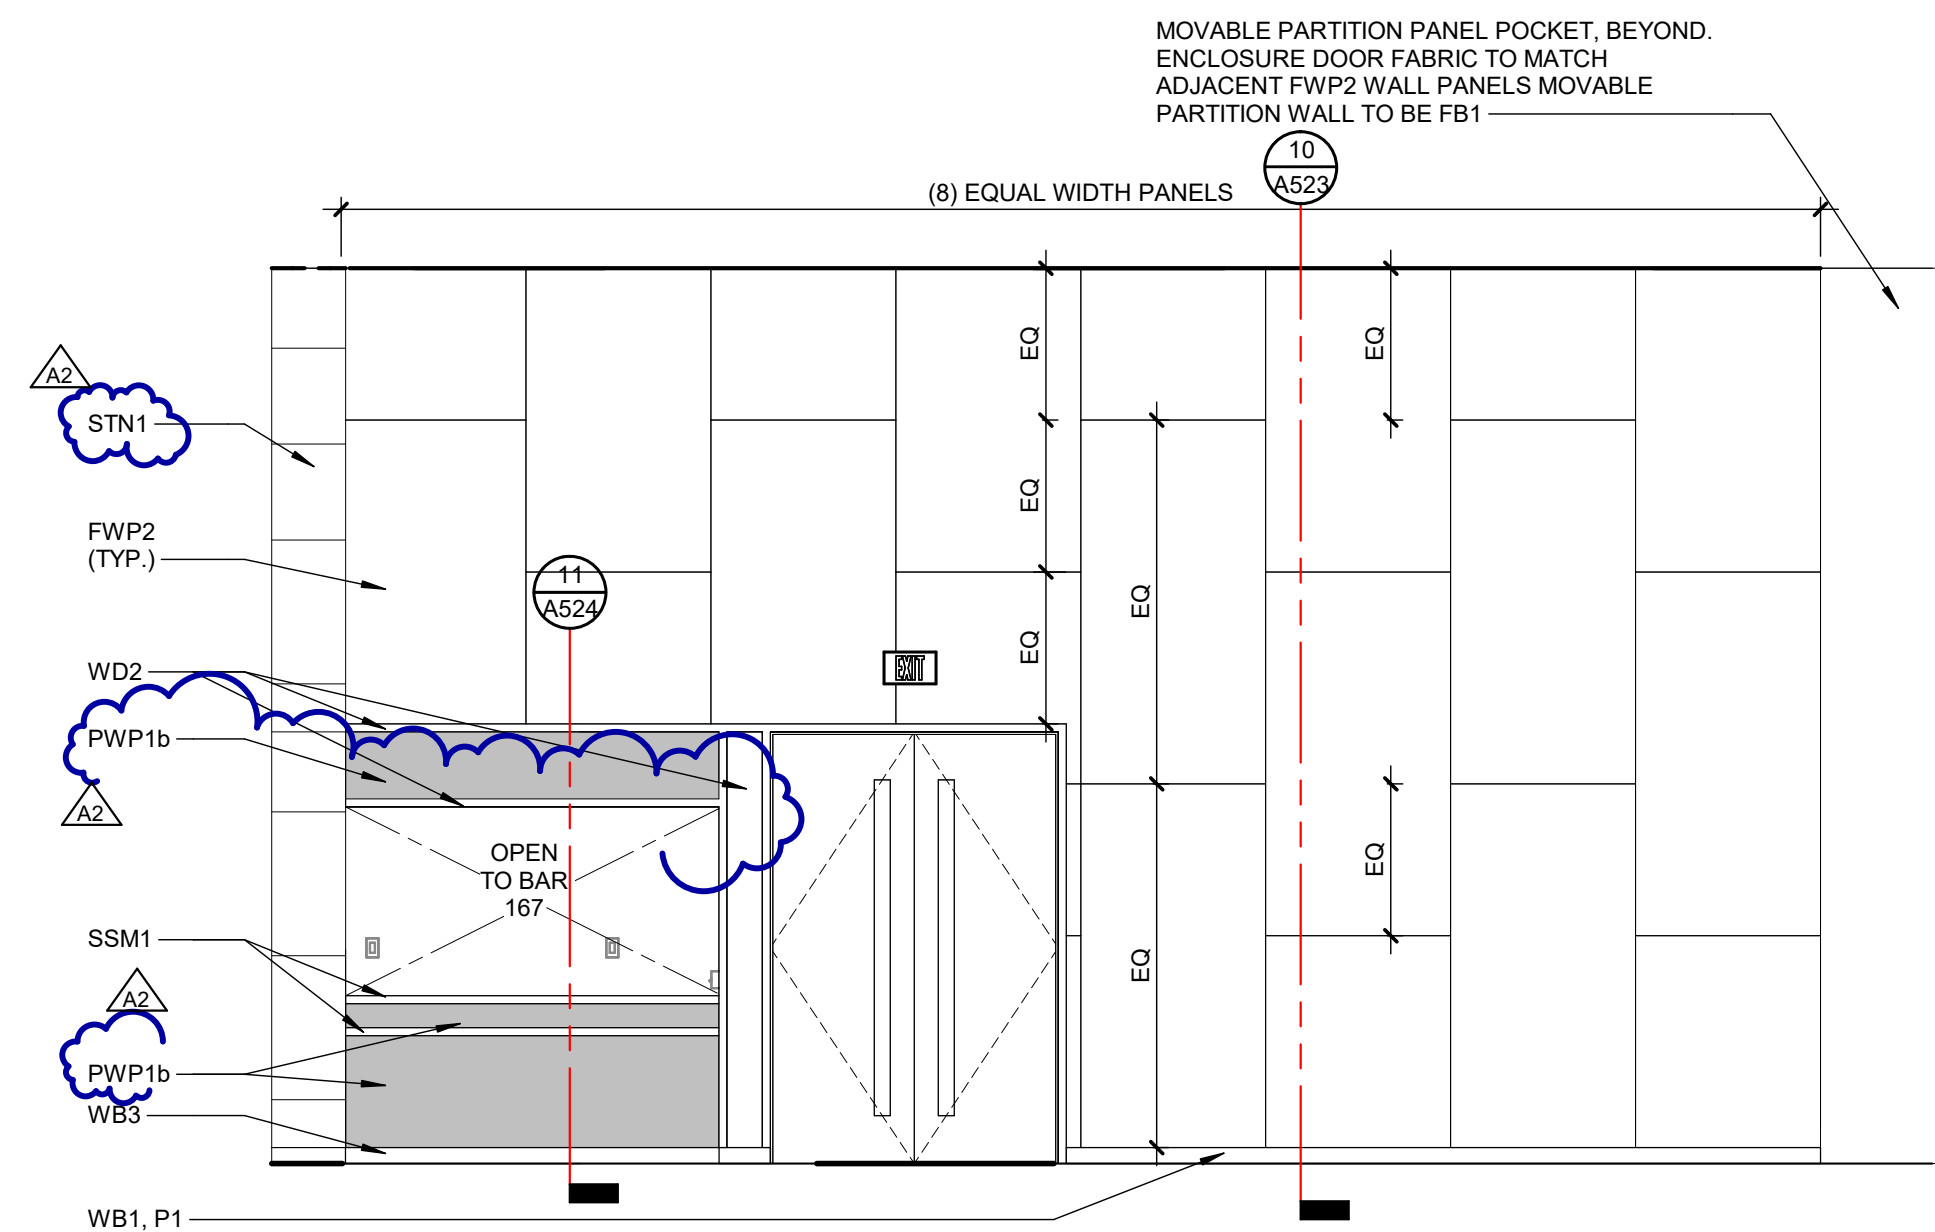

C BALLROOM 170 NORTH
INTERIOR ELEVATION
SCALE: 1/4" = 1'-0"

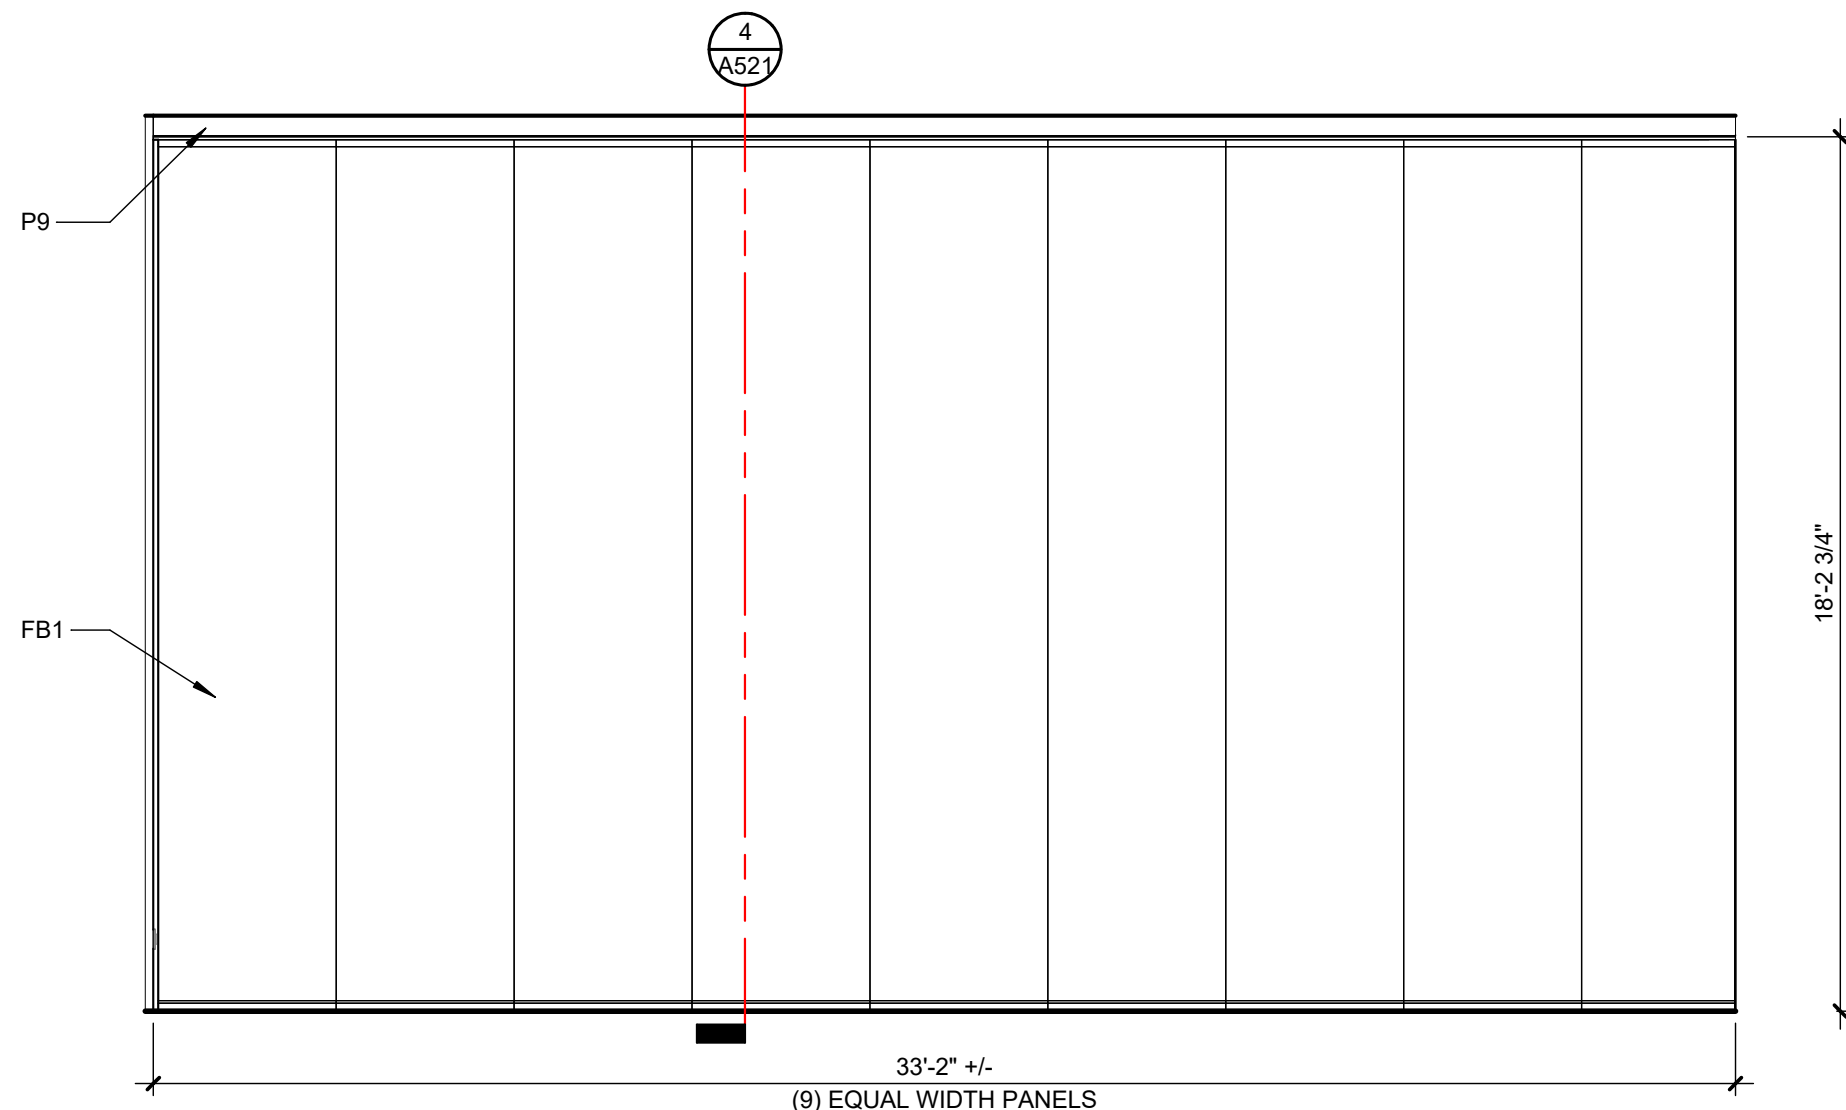

B BALLROOM 169 WEST
INTERIOR ELEVATION
SCALE: 1/4" = 1'-0"

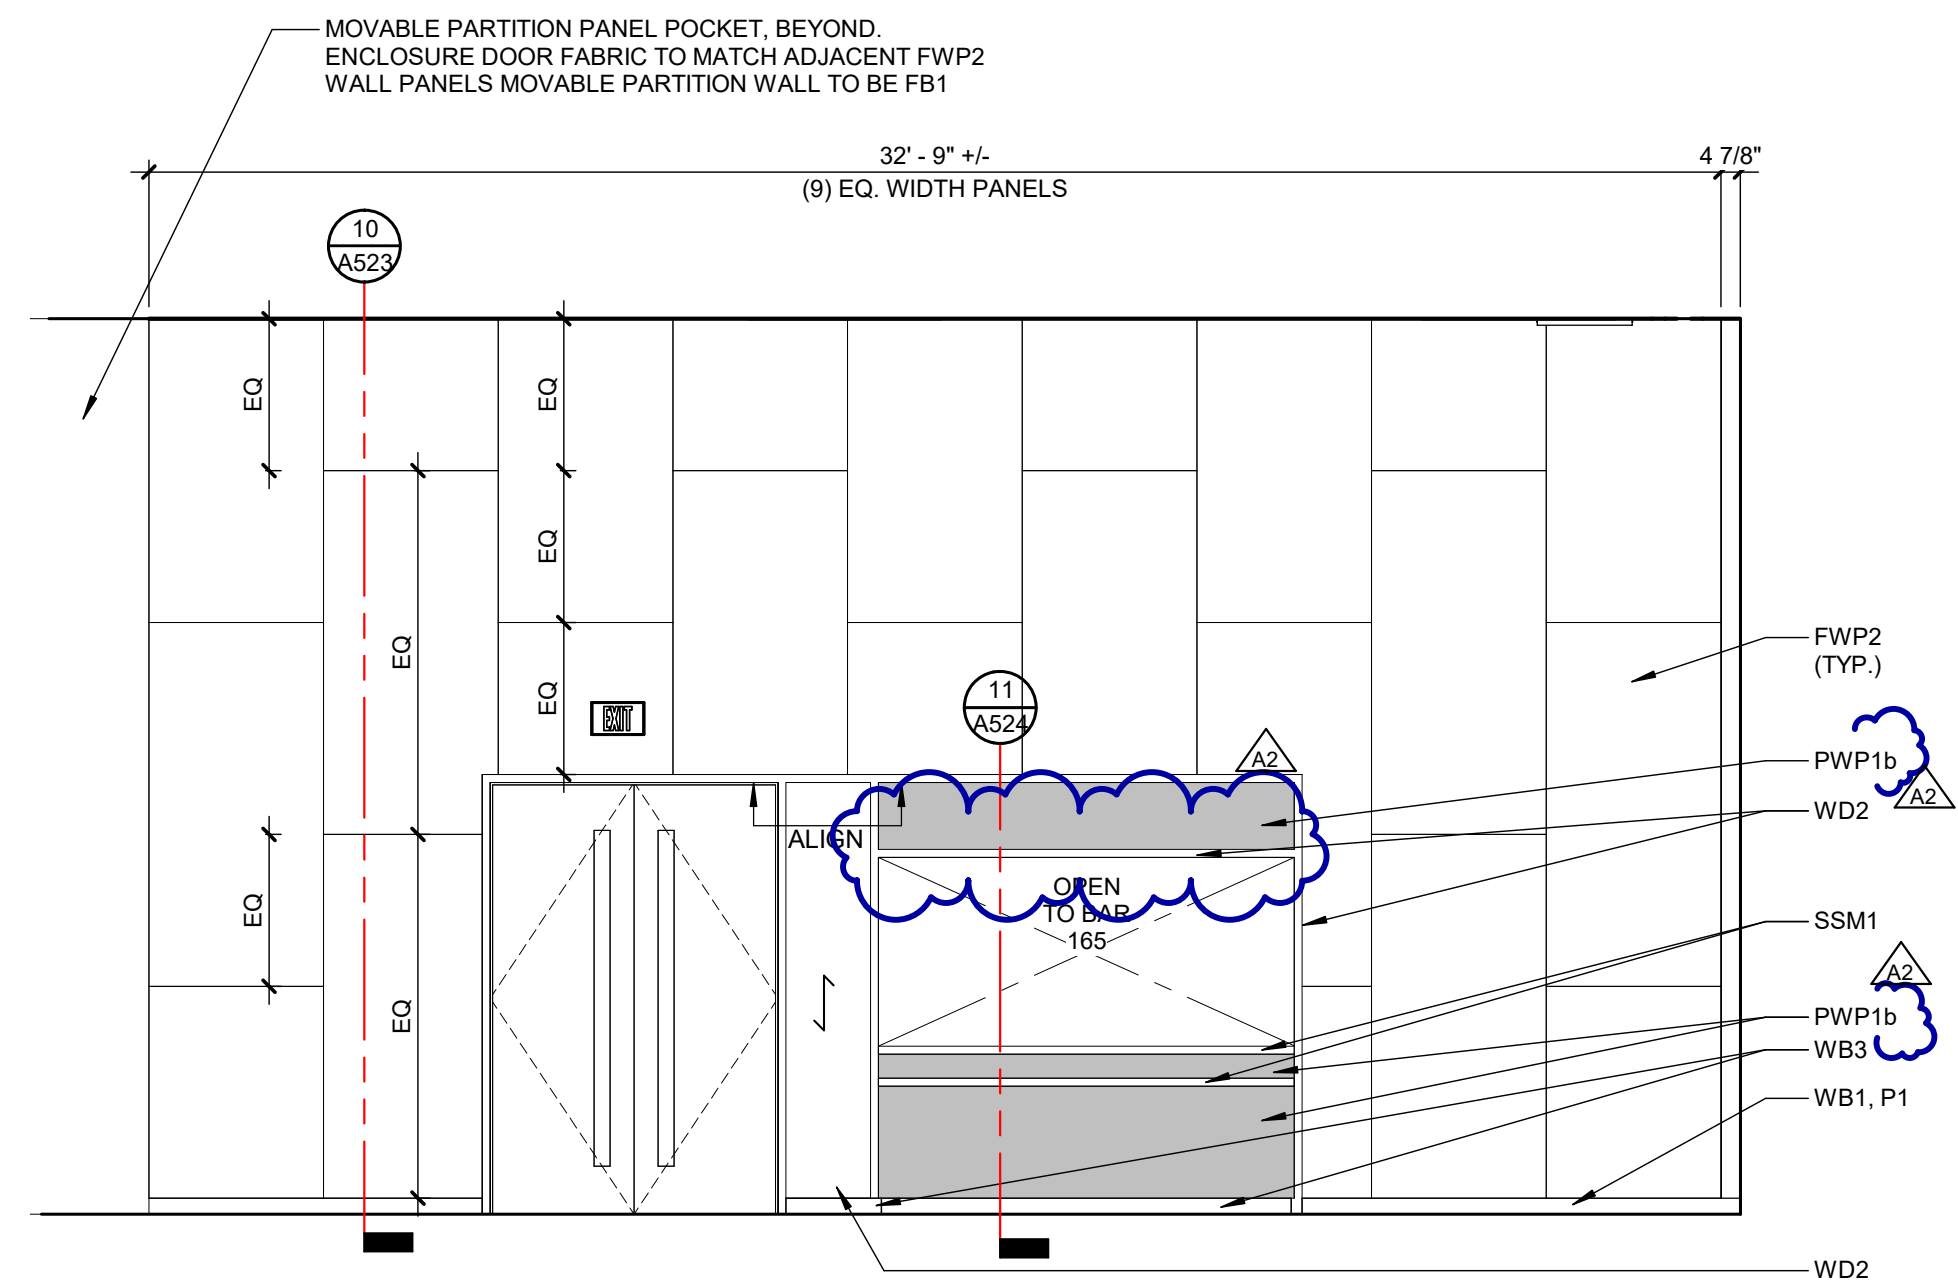

A BALLROOM 169 NORTH
INTERIOR ELEVATION
SCALE: 1/4" = 1'-0"

REVISIONS		
10/27/2026	A2	ADDENDUM NO. 2

10/12/2026	BIDS & PERMIT
09/21/2026	CD PEER REVIEW
09/09/2026	CD TEAM REVIEW
08/10/2026	CD 50% PROGRESS
08/22/2026	DD OWNER REVIEW
08/15/2026	DD PEER REVIEW
08/08/2026	DD 90 % PROGRESS
08/18/2026	DD 90 % PROGRESS
02/23/2026	SD OWNER REVIEW
02/13/2026	SD PEER REVIEW
02/09/2026	SD PROGRESS REVIEW


Drawn By	KBRAUN
Designer	KBRAUN
Reviewer	WLAPSON
Manager	CKRETOVIC

Hard copy is intended to be 24"x36" when plotted. Scale(s) indicated and graphic quality may not be accurate for any other size.

PROJECT NO.
2500281

SHEET NO.

A324

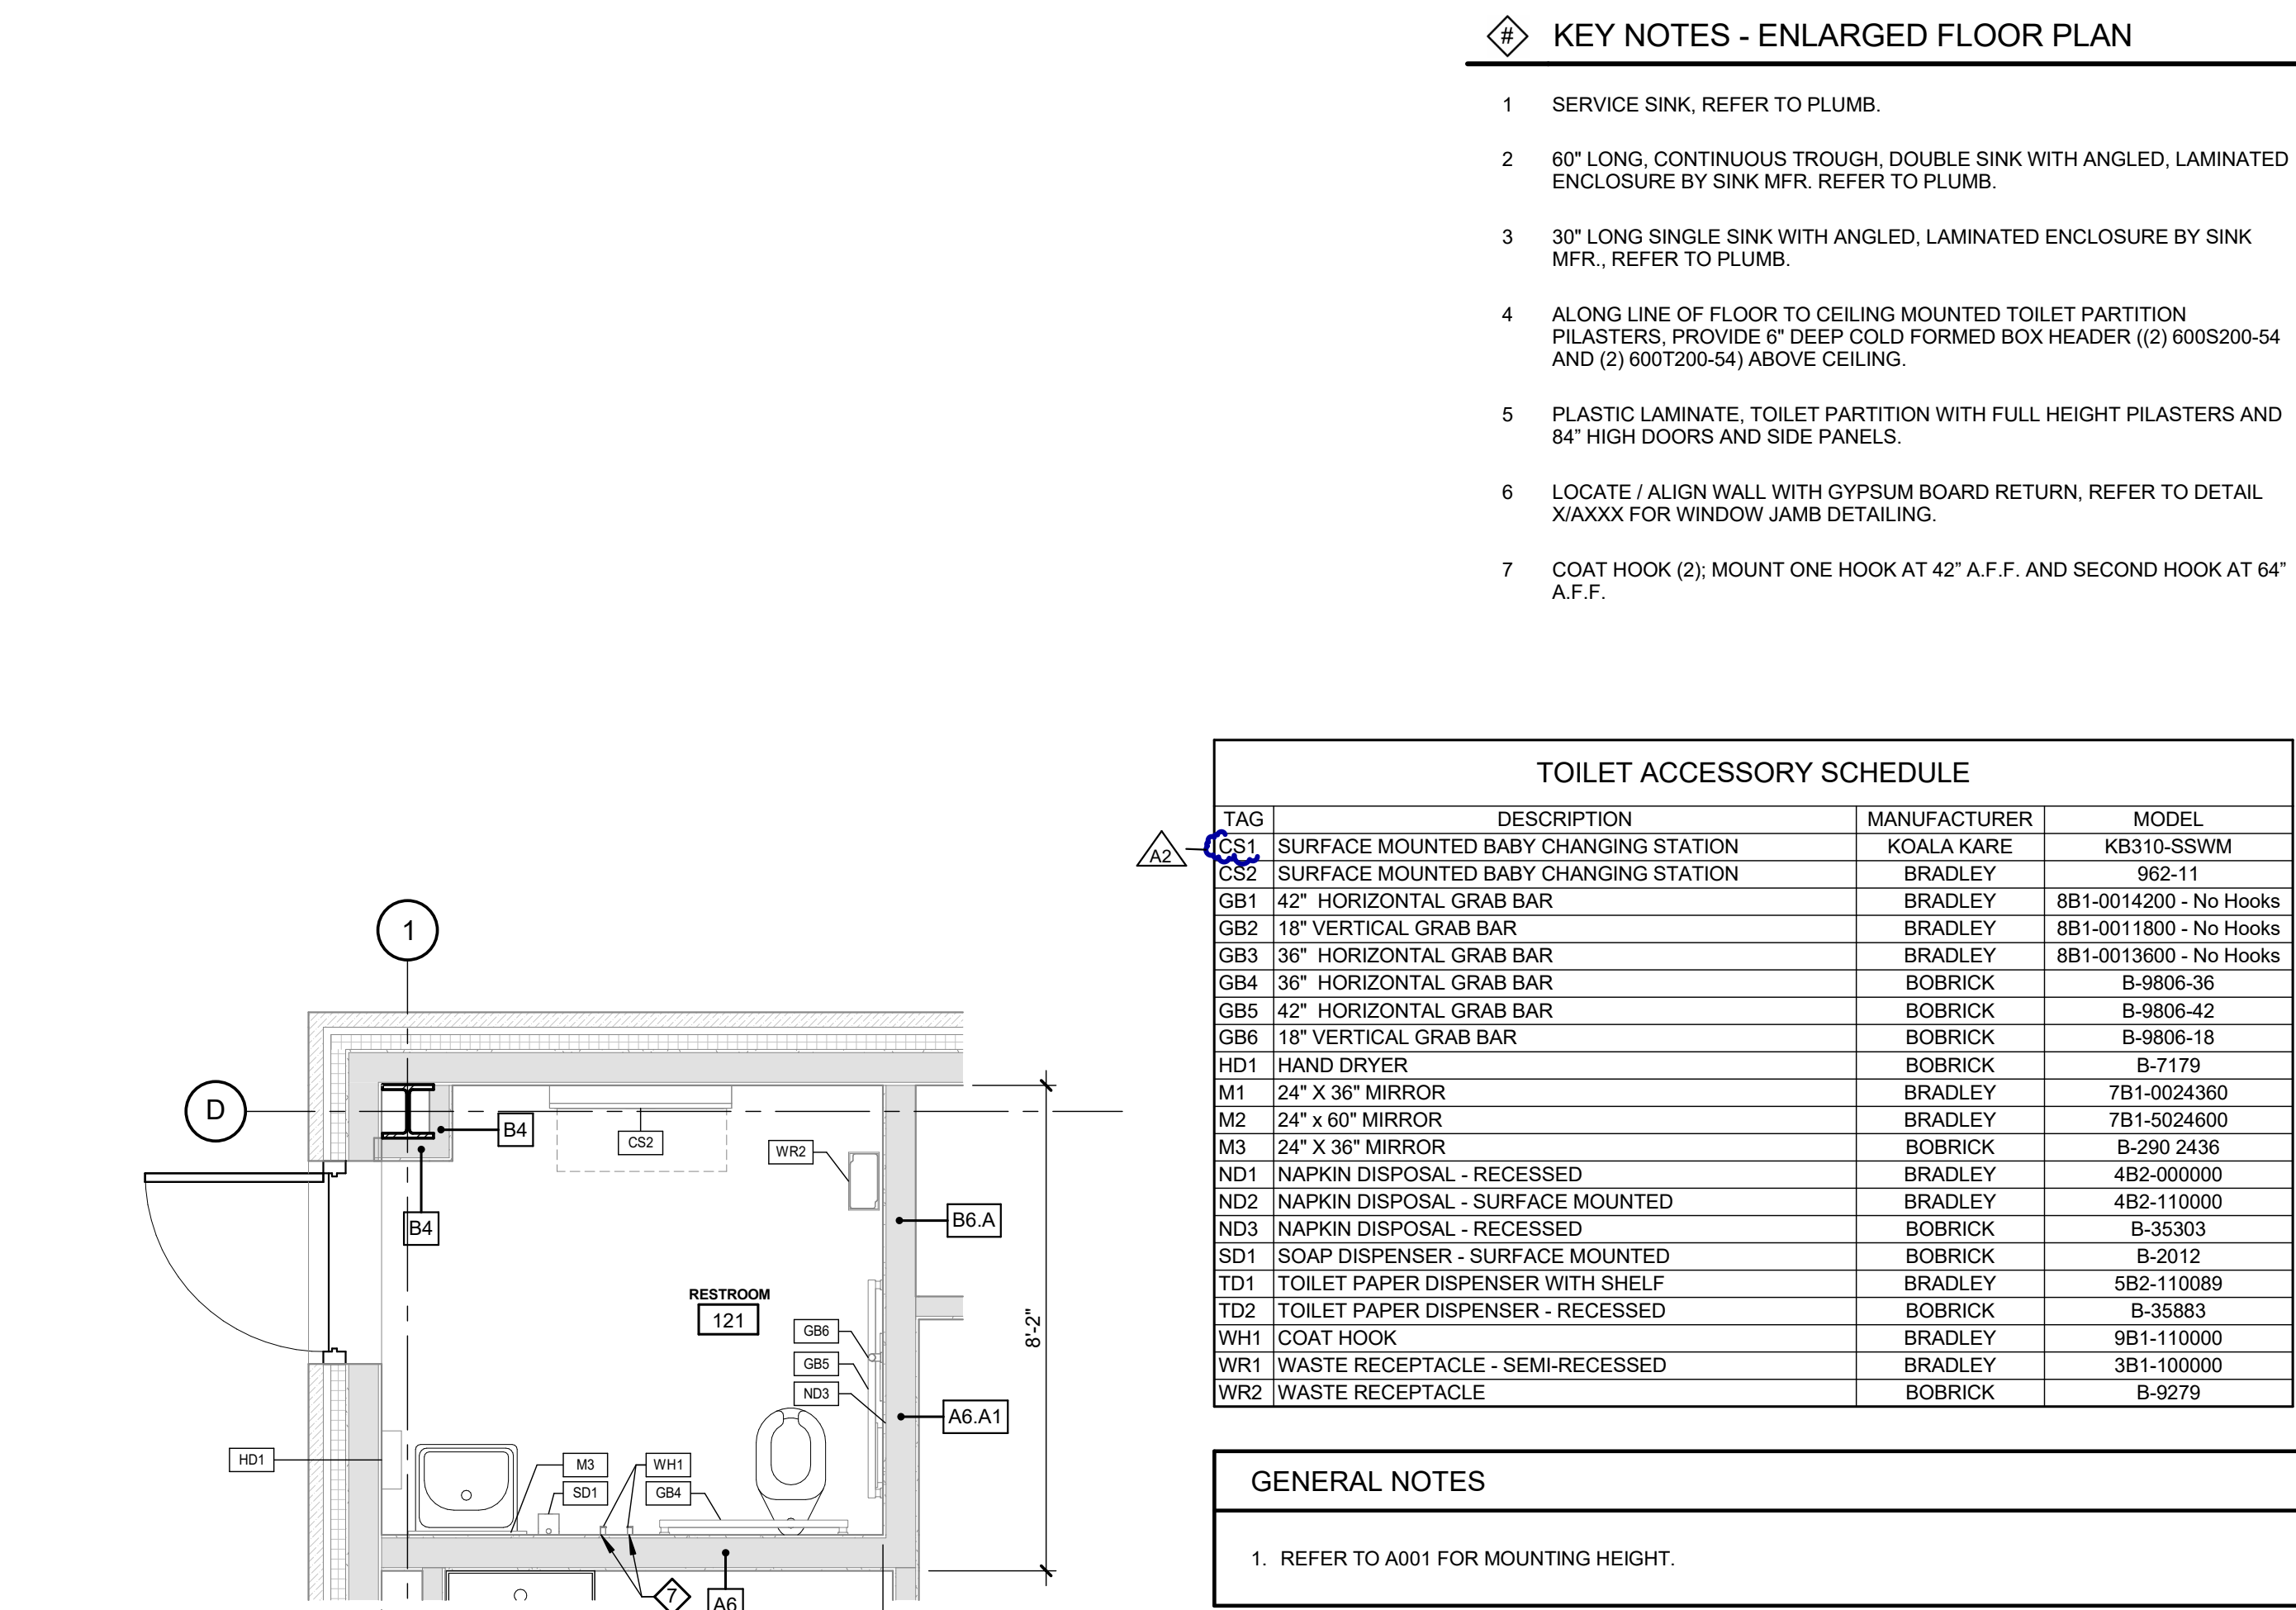

REVISIONS		
10/27/2026	A2	ADDENDUM NO. 2


10/12/2026	BIDS & PERMIT
09/21/2026	CD PEER REVIEW
09/09/2026	CD TEAM REVIEW
08/10/2026	CD 50% PROGRESS
08/22/2026	DD OWNER REVIEW
06/15/2026	DD PEER REVIEW
06/08/2026	DD 90 % PROGRESS
05/18/2026	DD 50 % PROGRESS
02/23/2026	SD OWNER REVIEW
02/13/2026	SD PEER REVIEW
02/09/2026	SD PROGRESS REVIEW


Drawn By IOLKHOVESKA
Designer IELHENNAWY
Reviewer WLRAPSON
Manager CKRETOVIC













Hard copy is intended to be 24"x36" when plotted. Scale(s) indicated and graphic quality may not be accurate for any other size.

PROJECT NO.
2500281

SHEET NO.

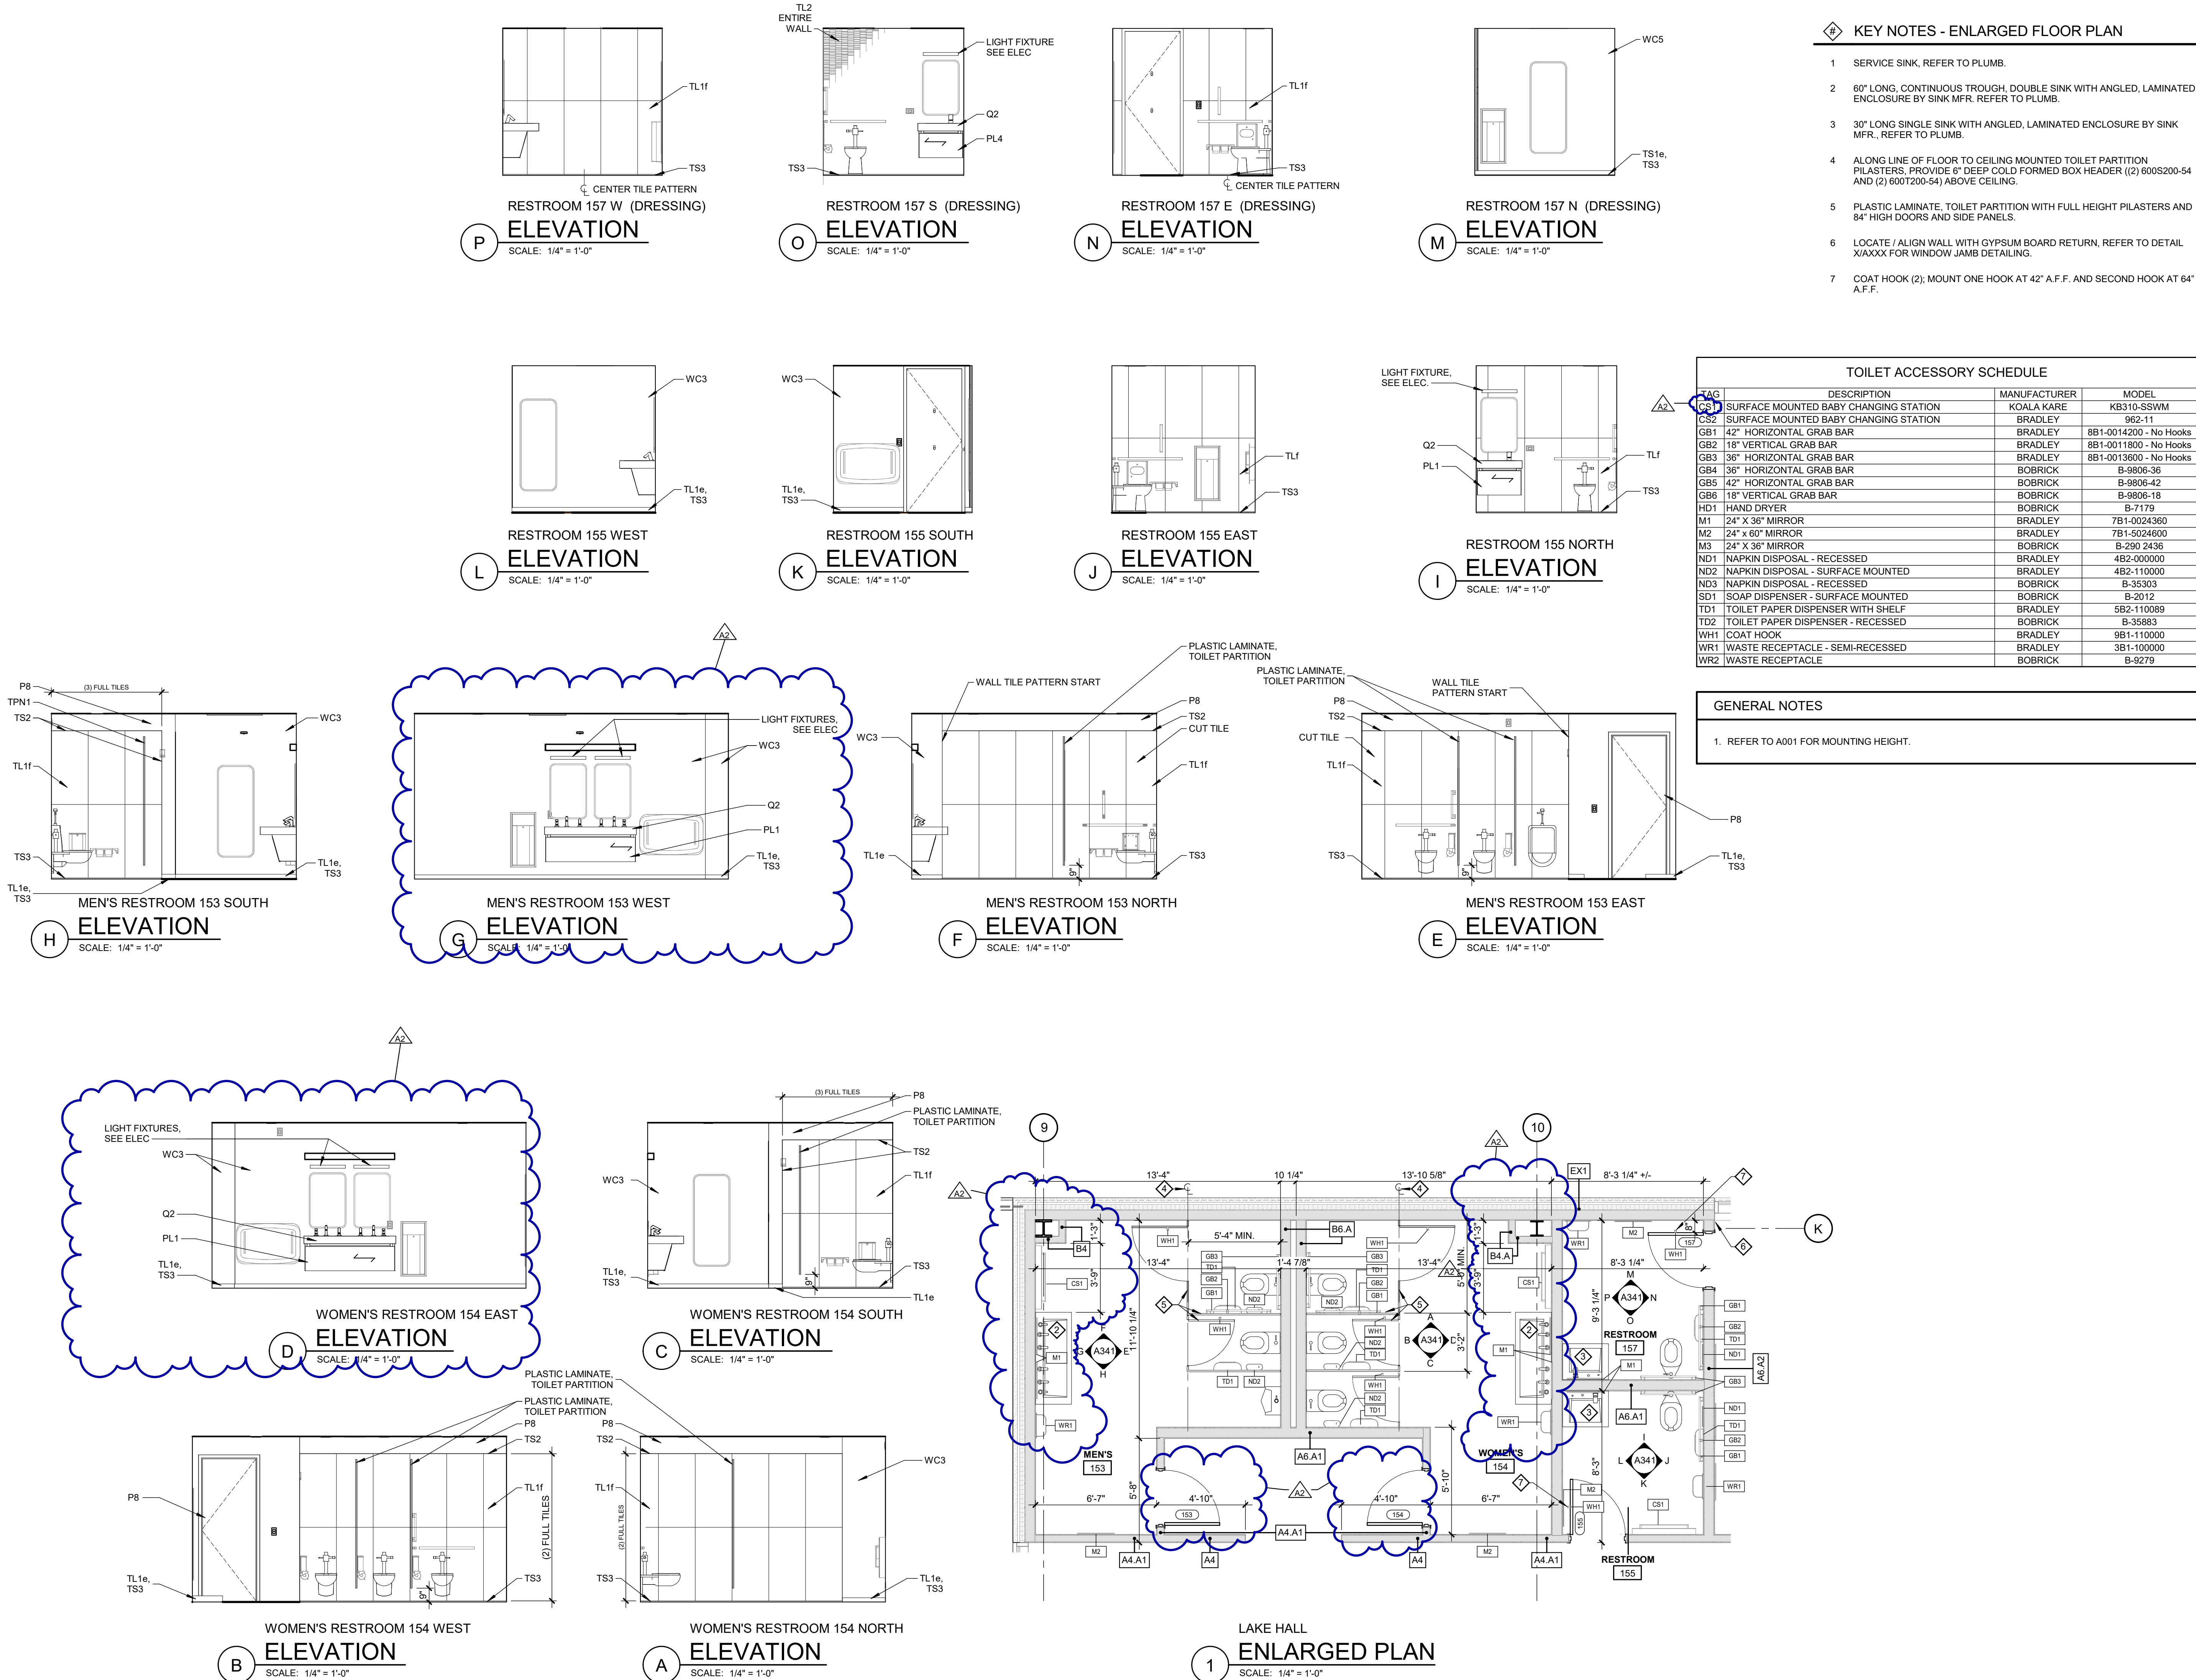

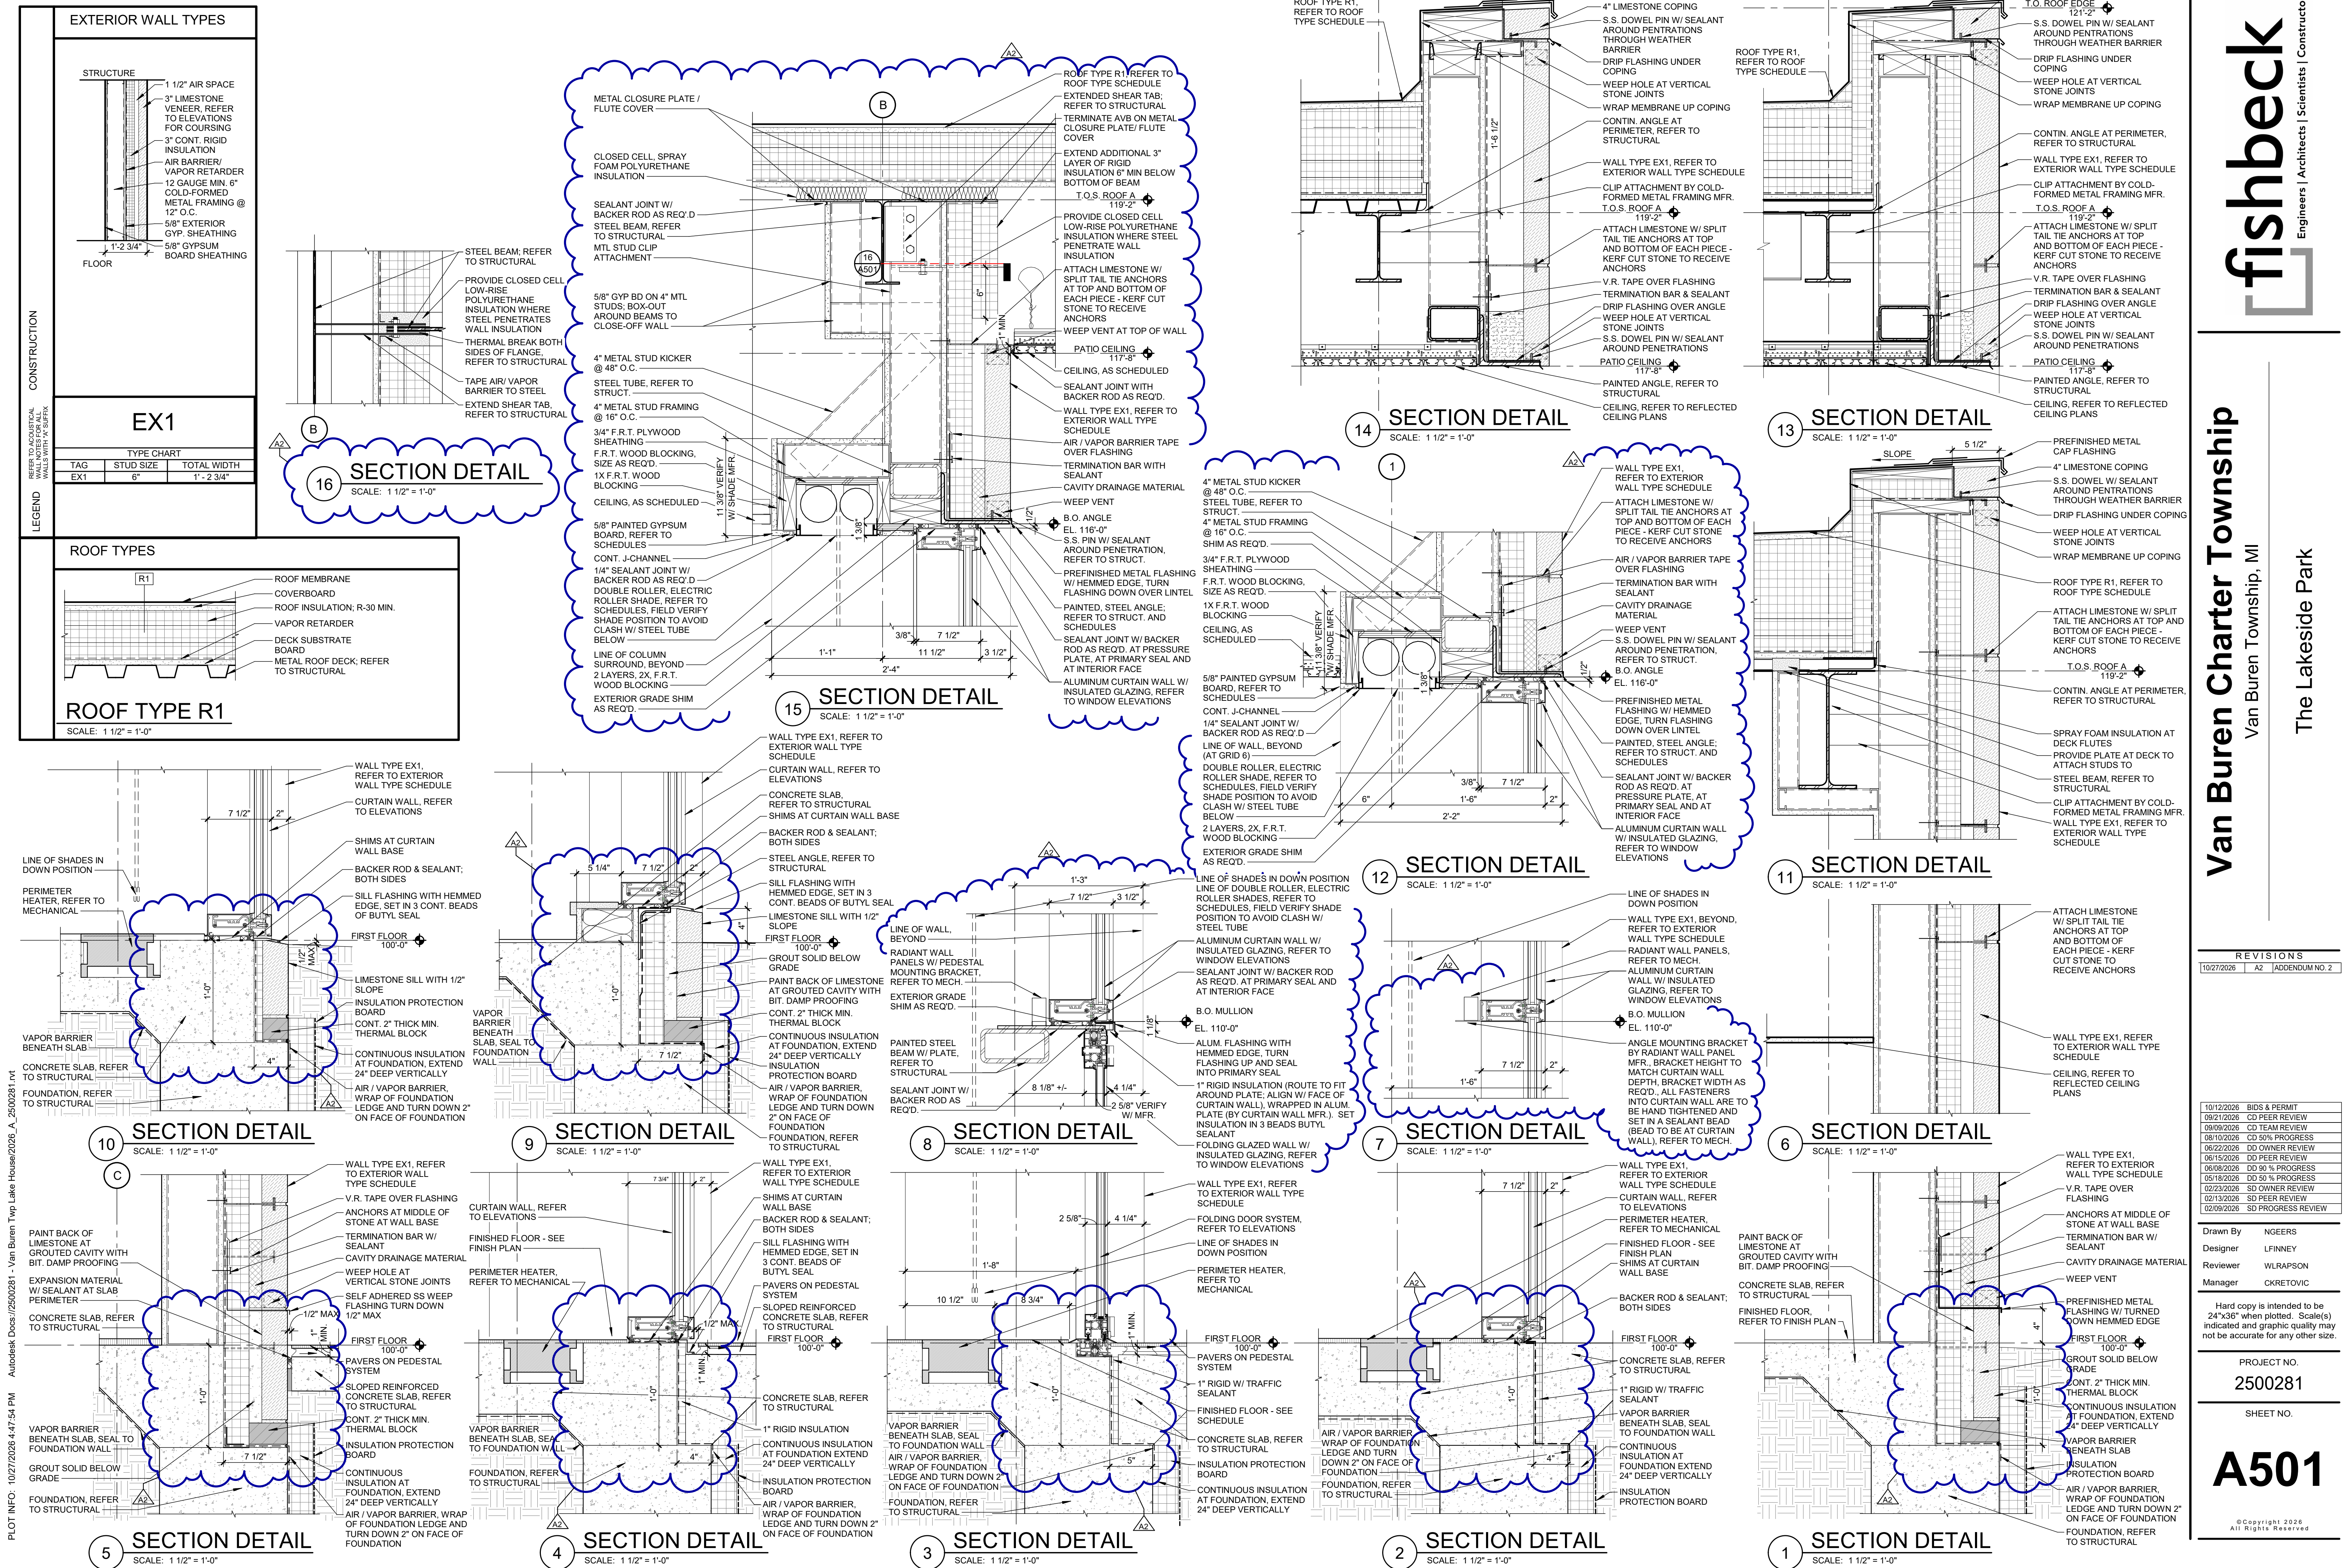

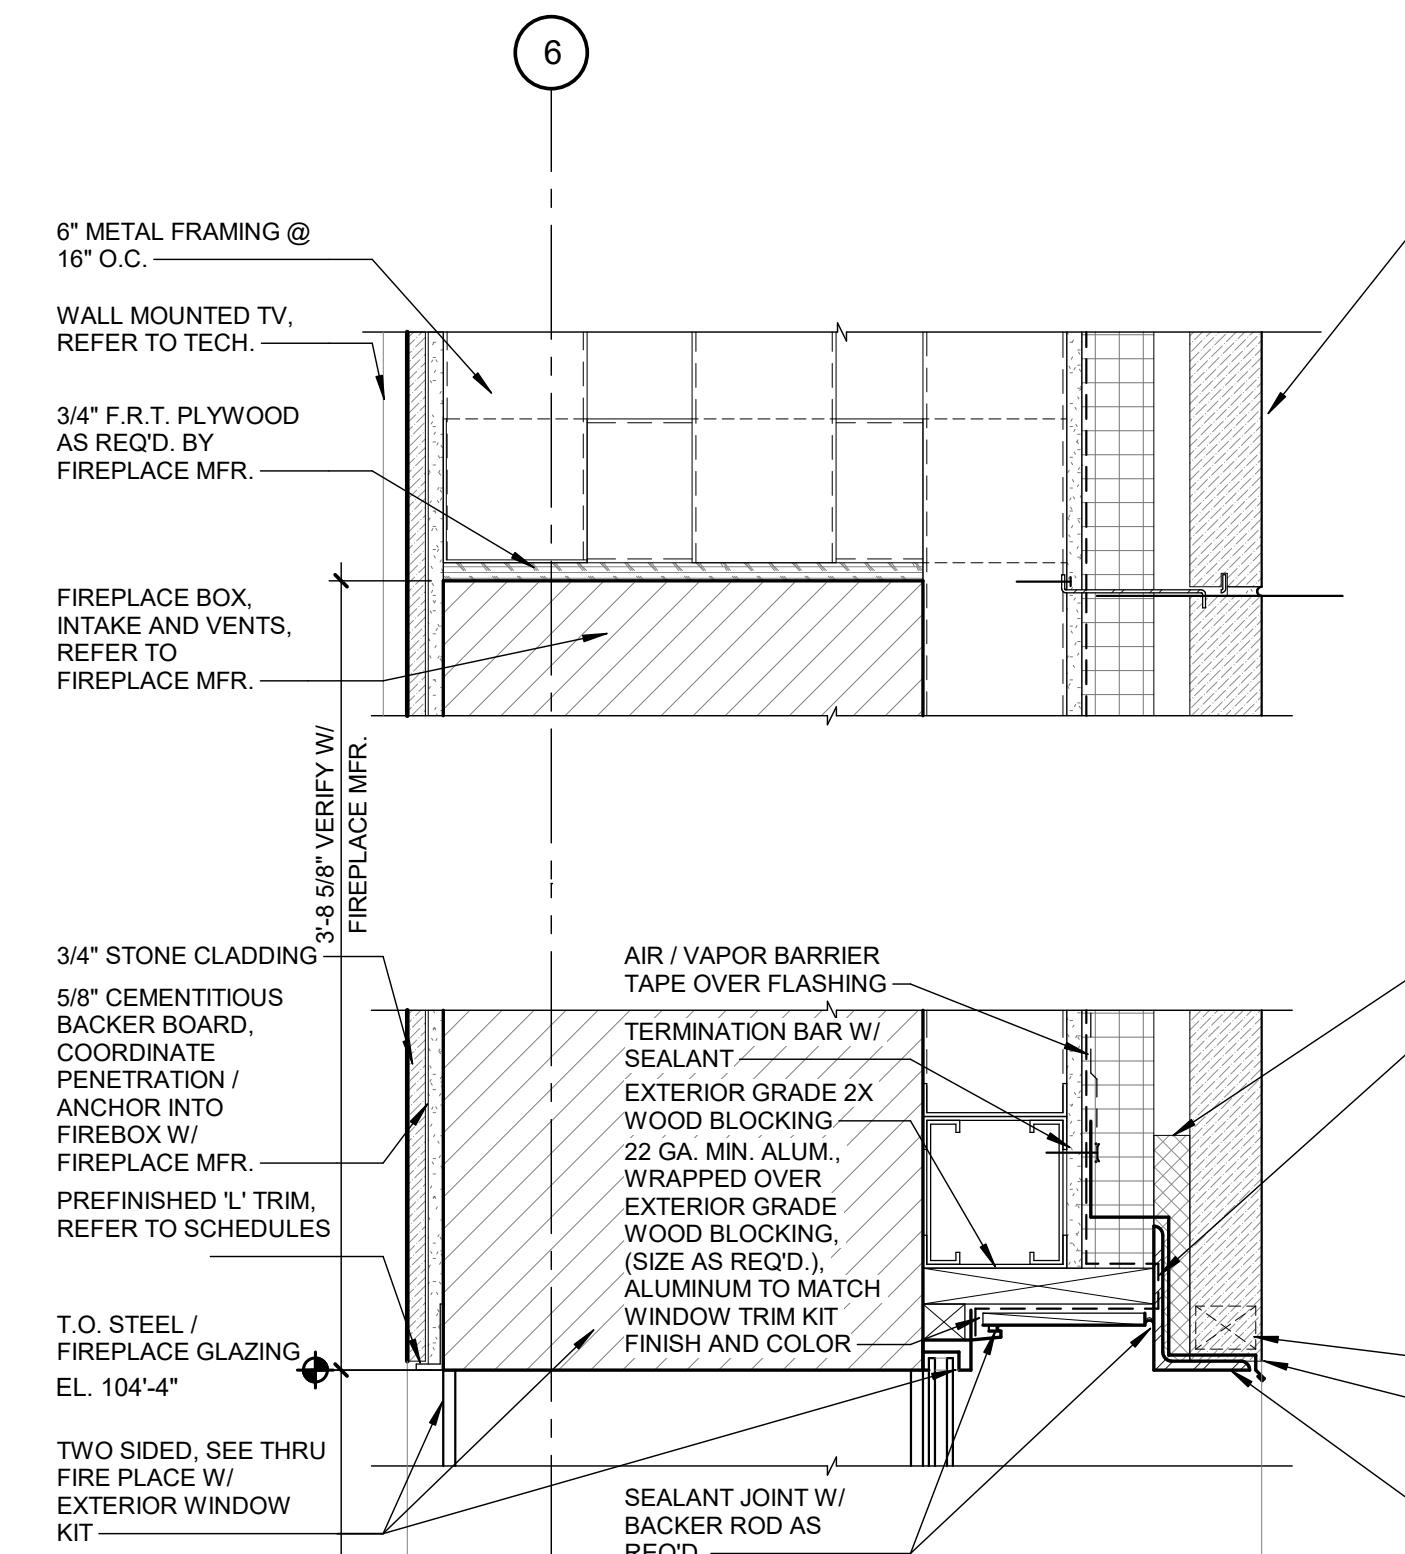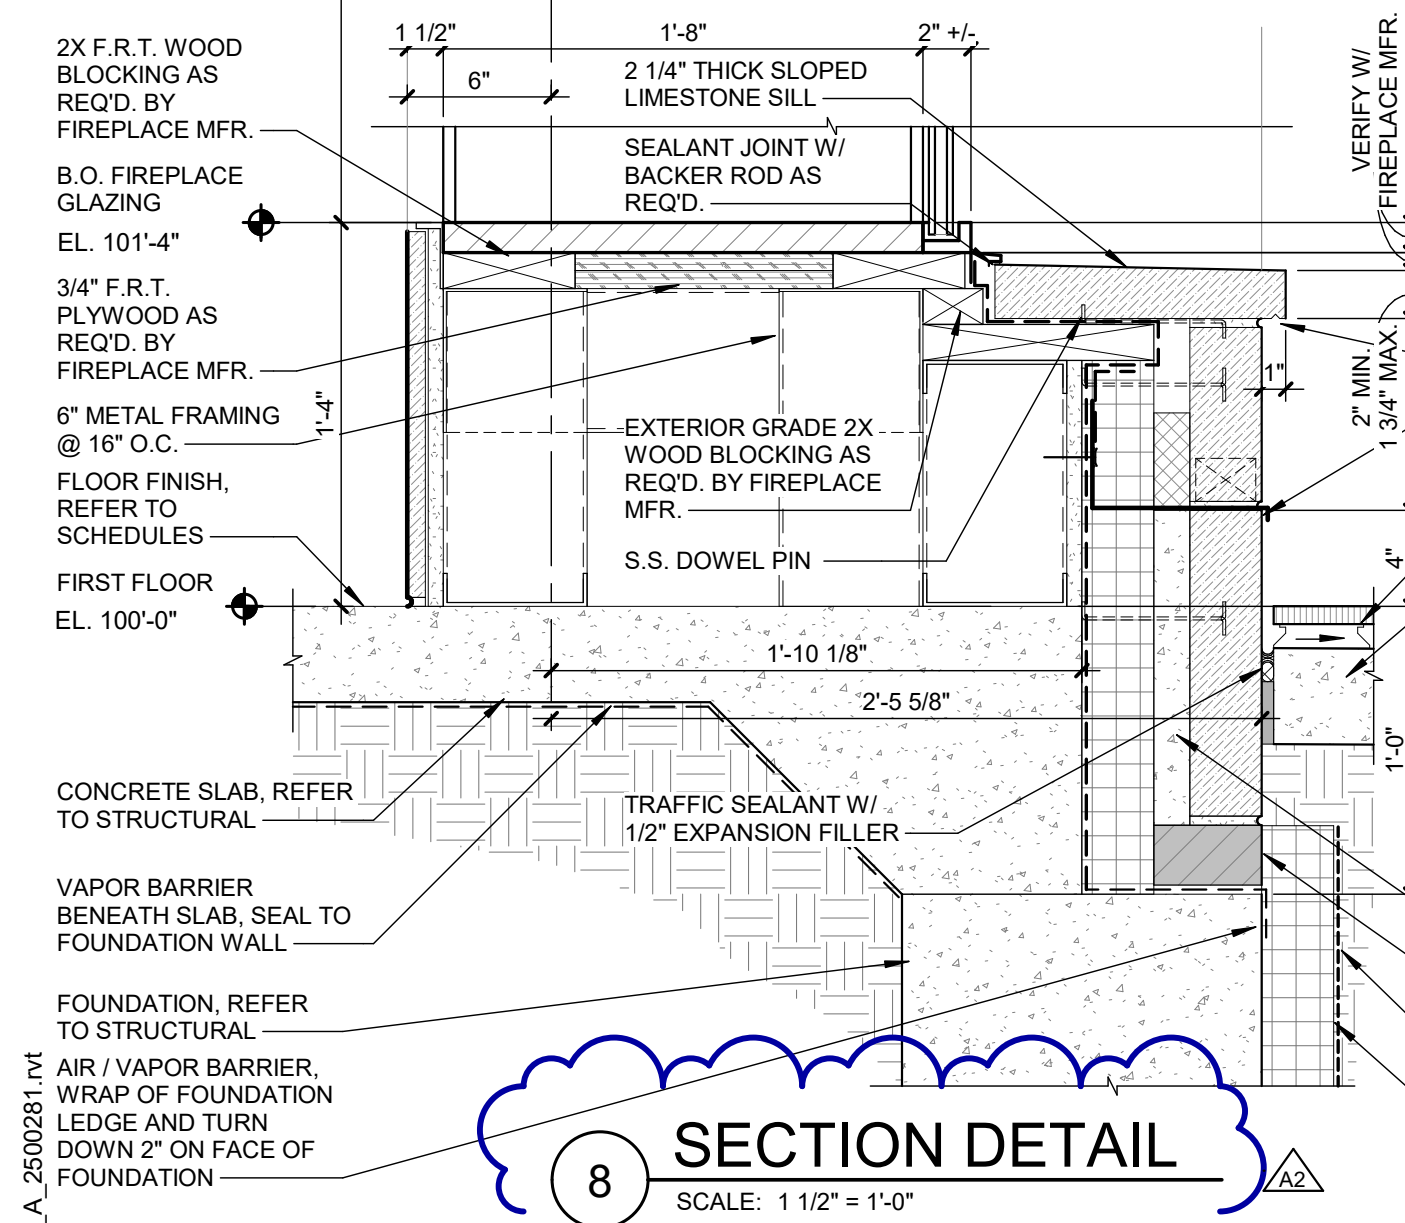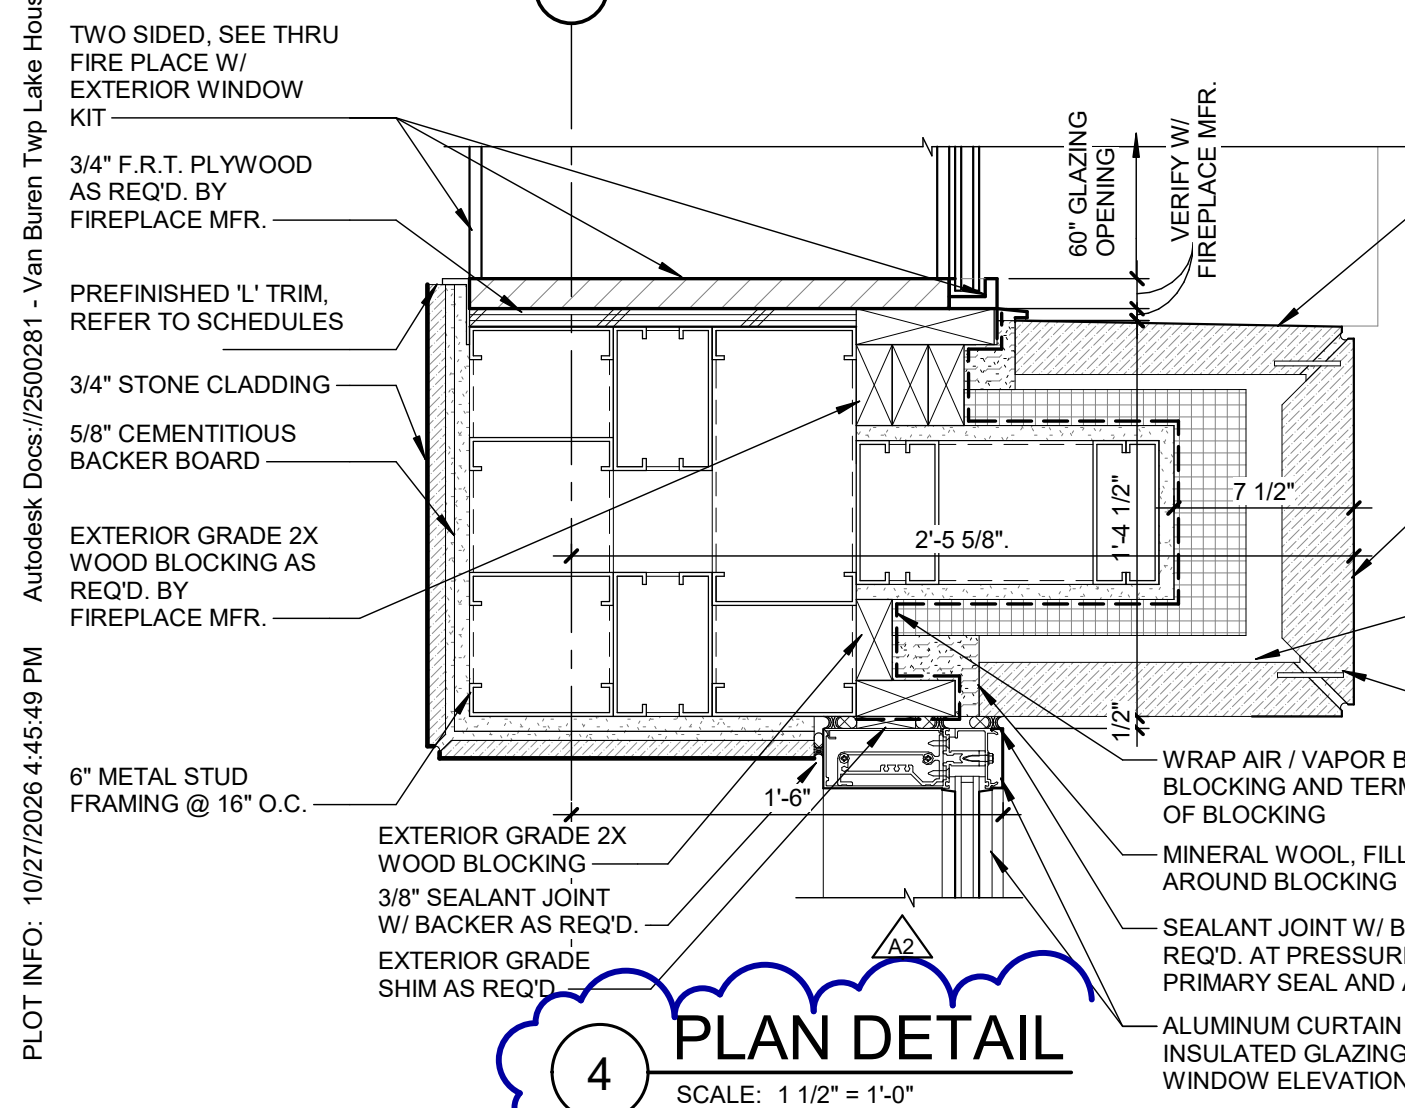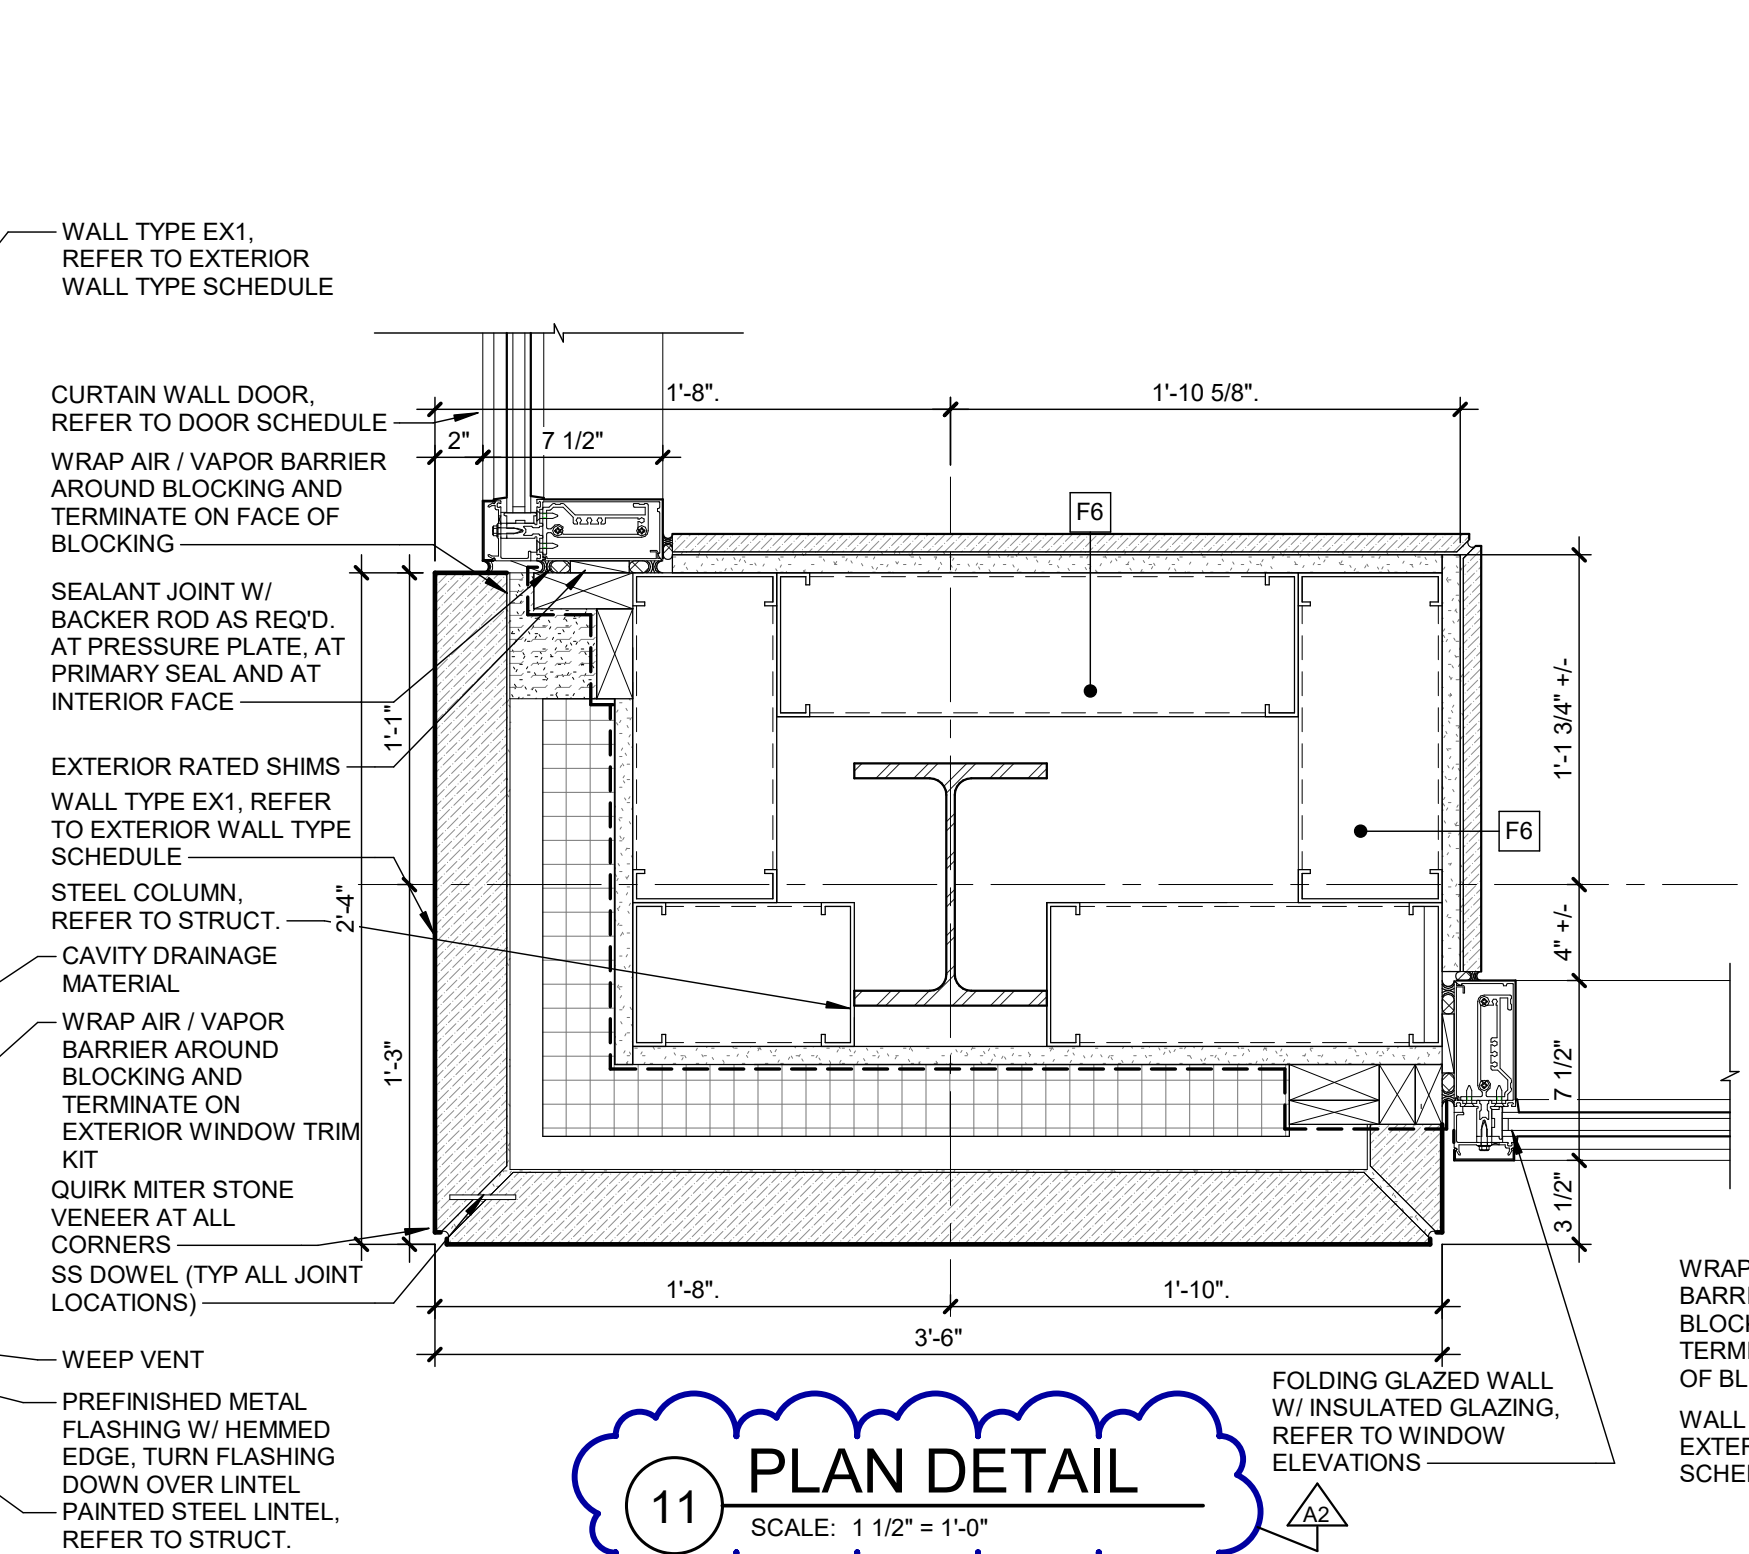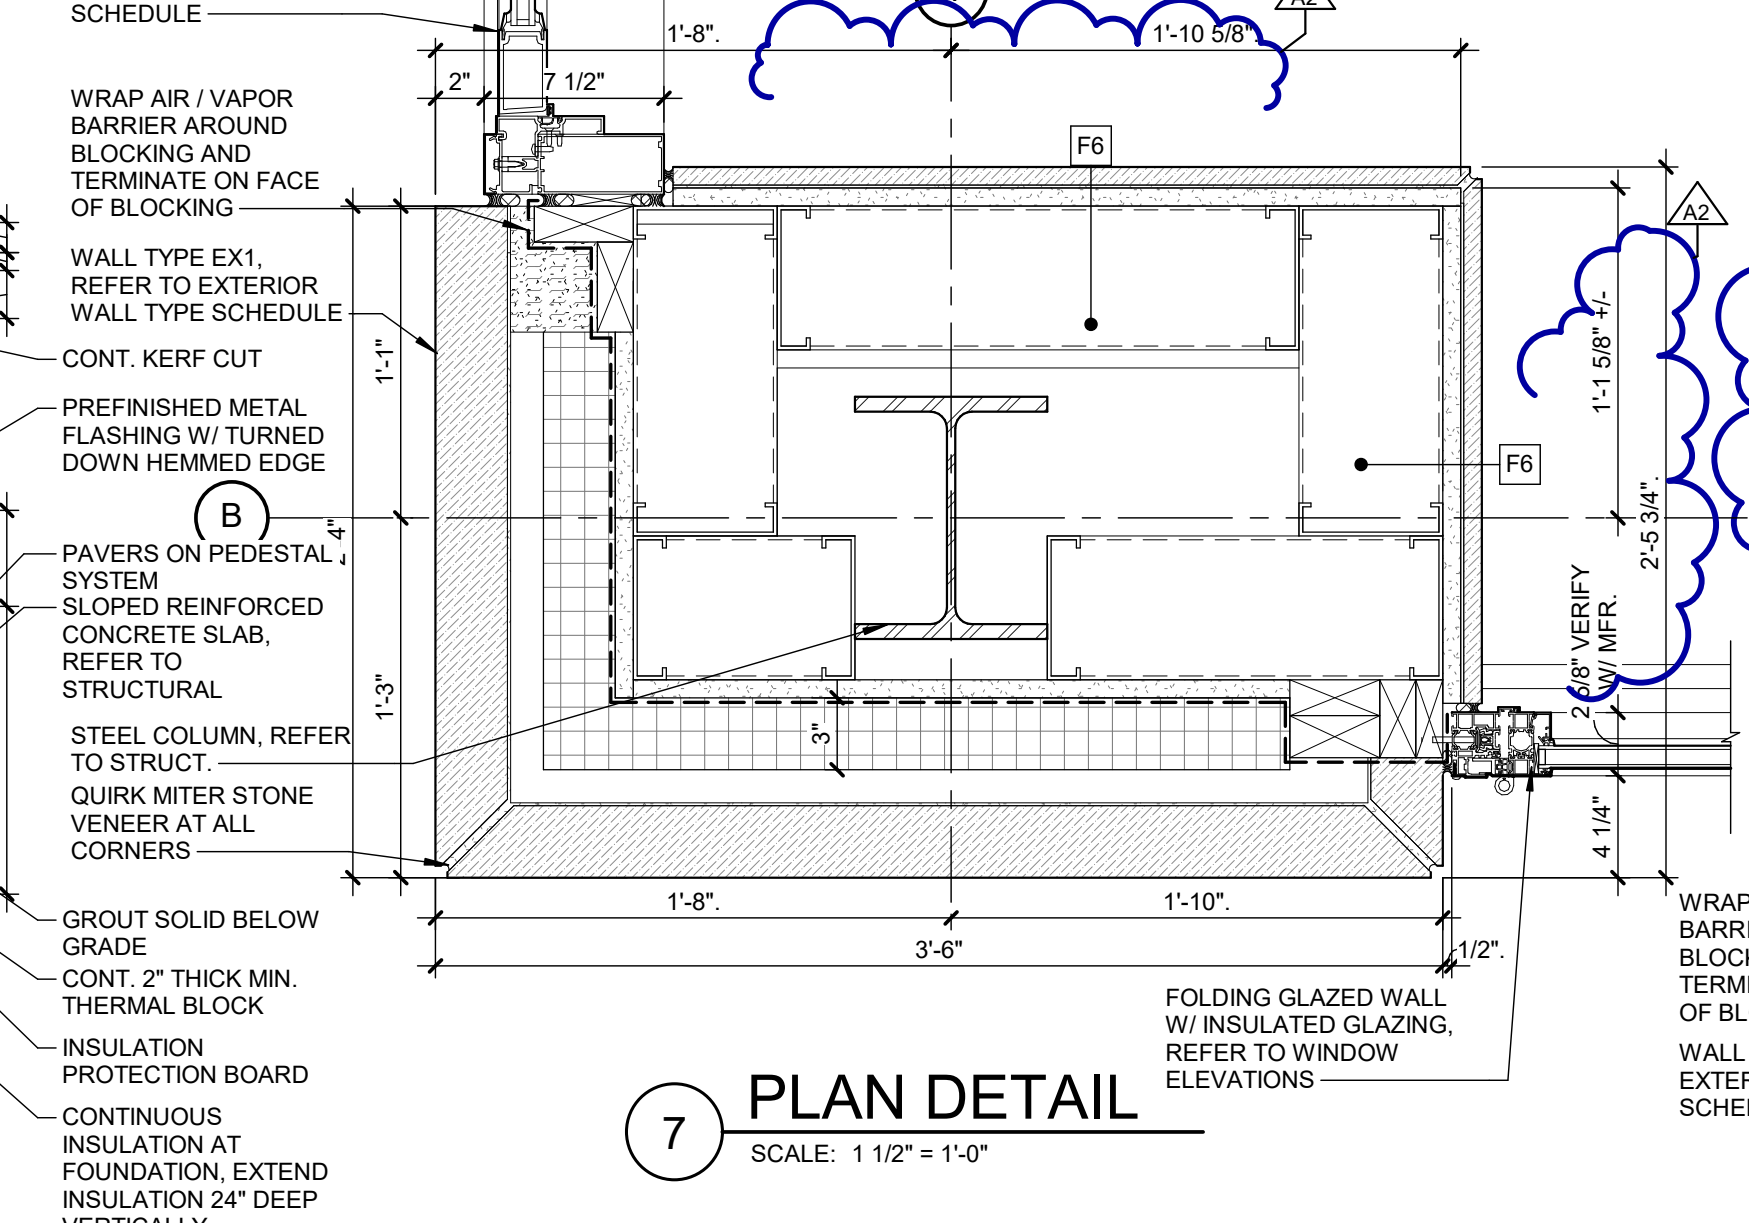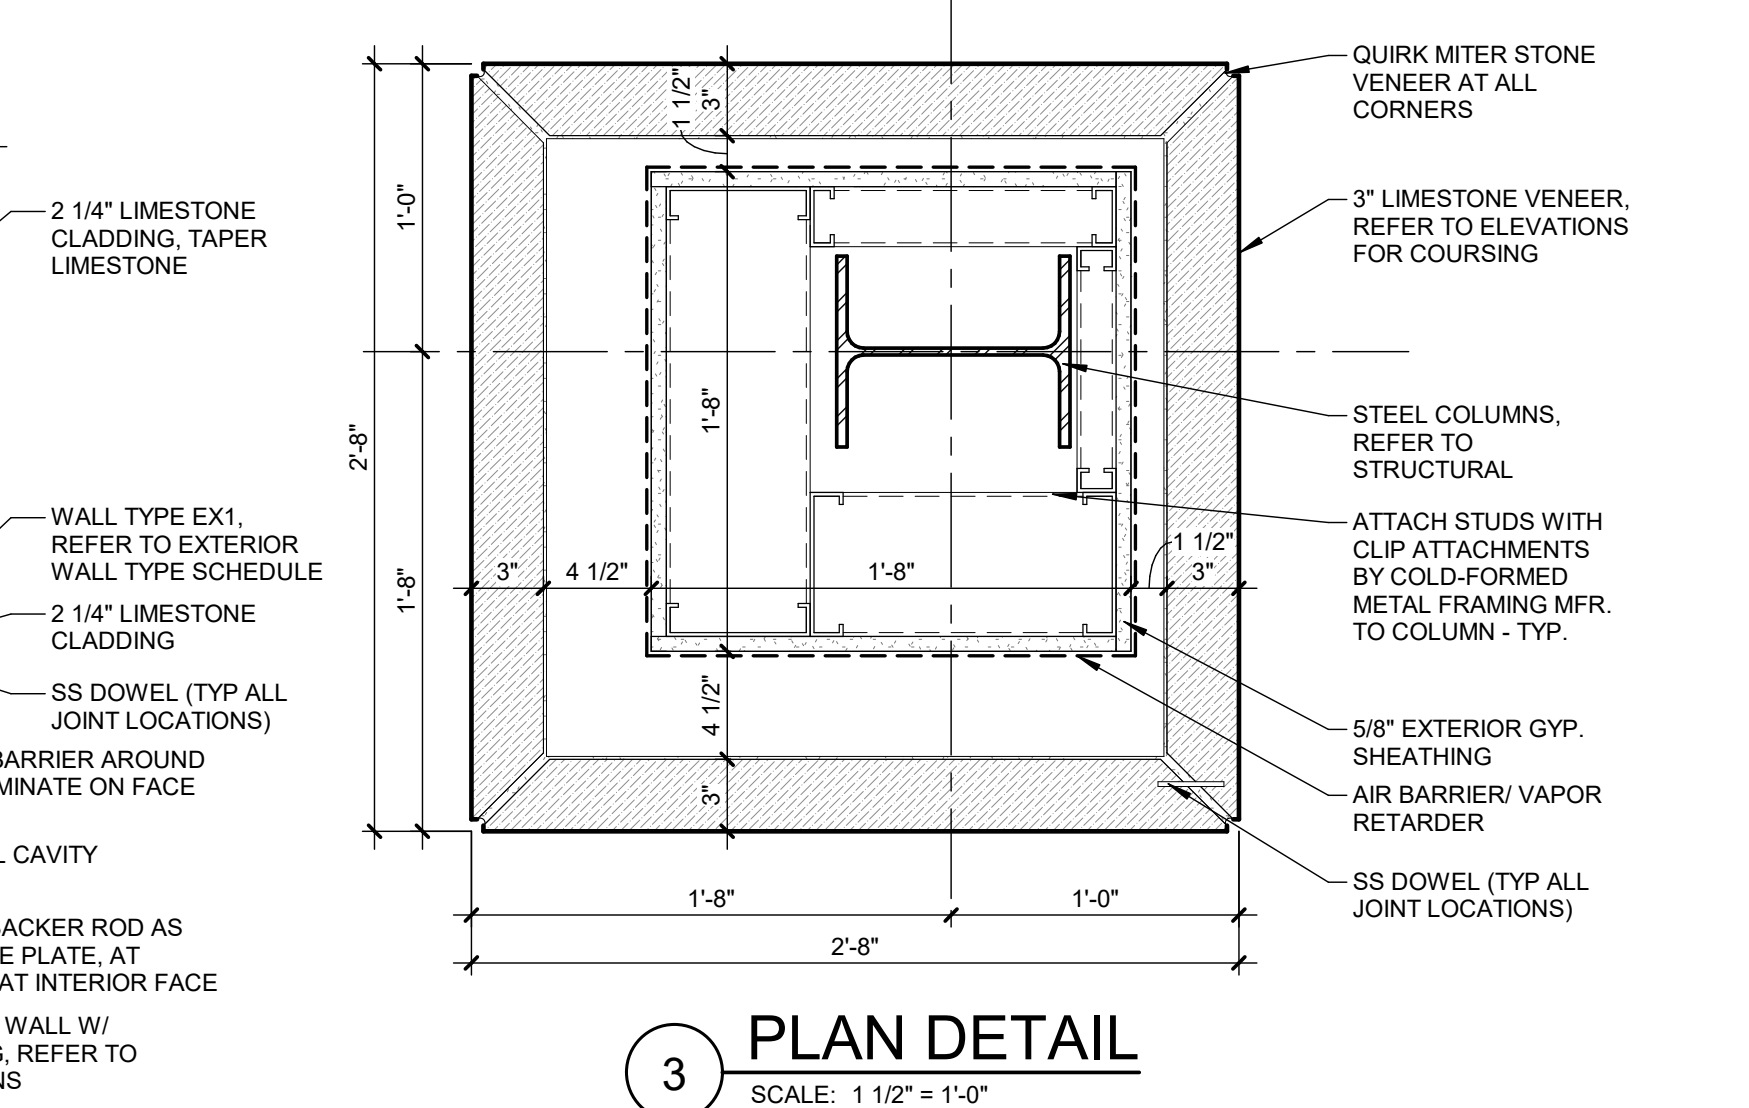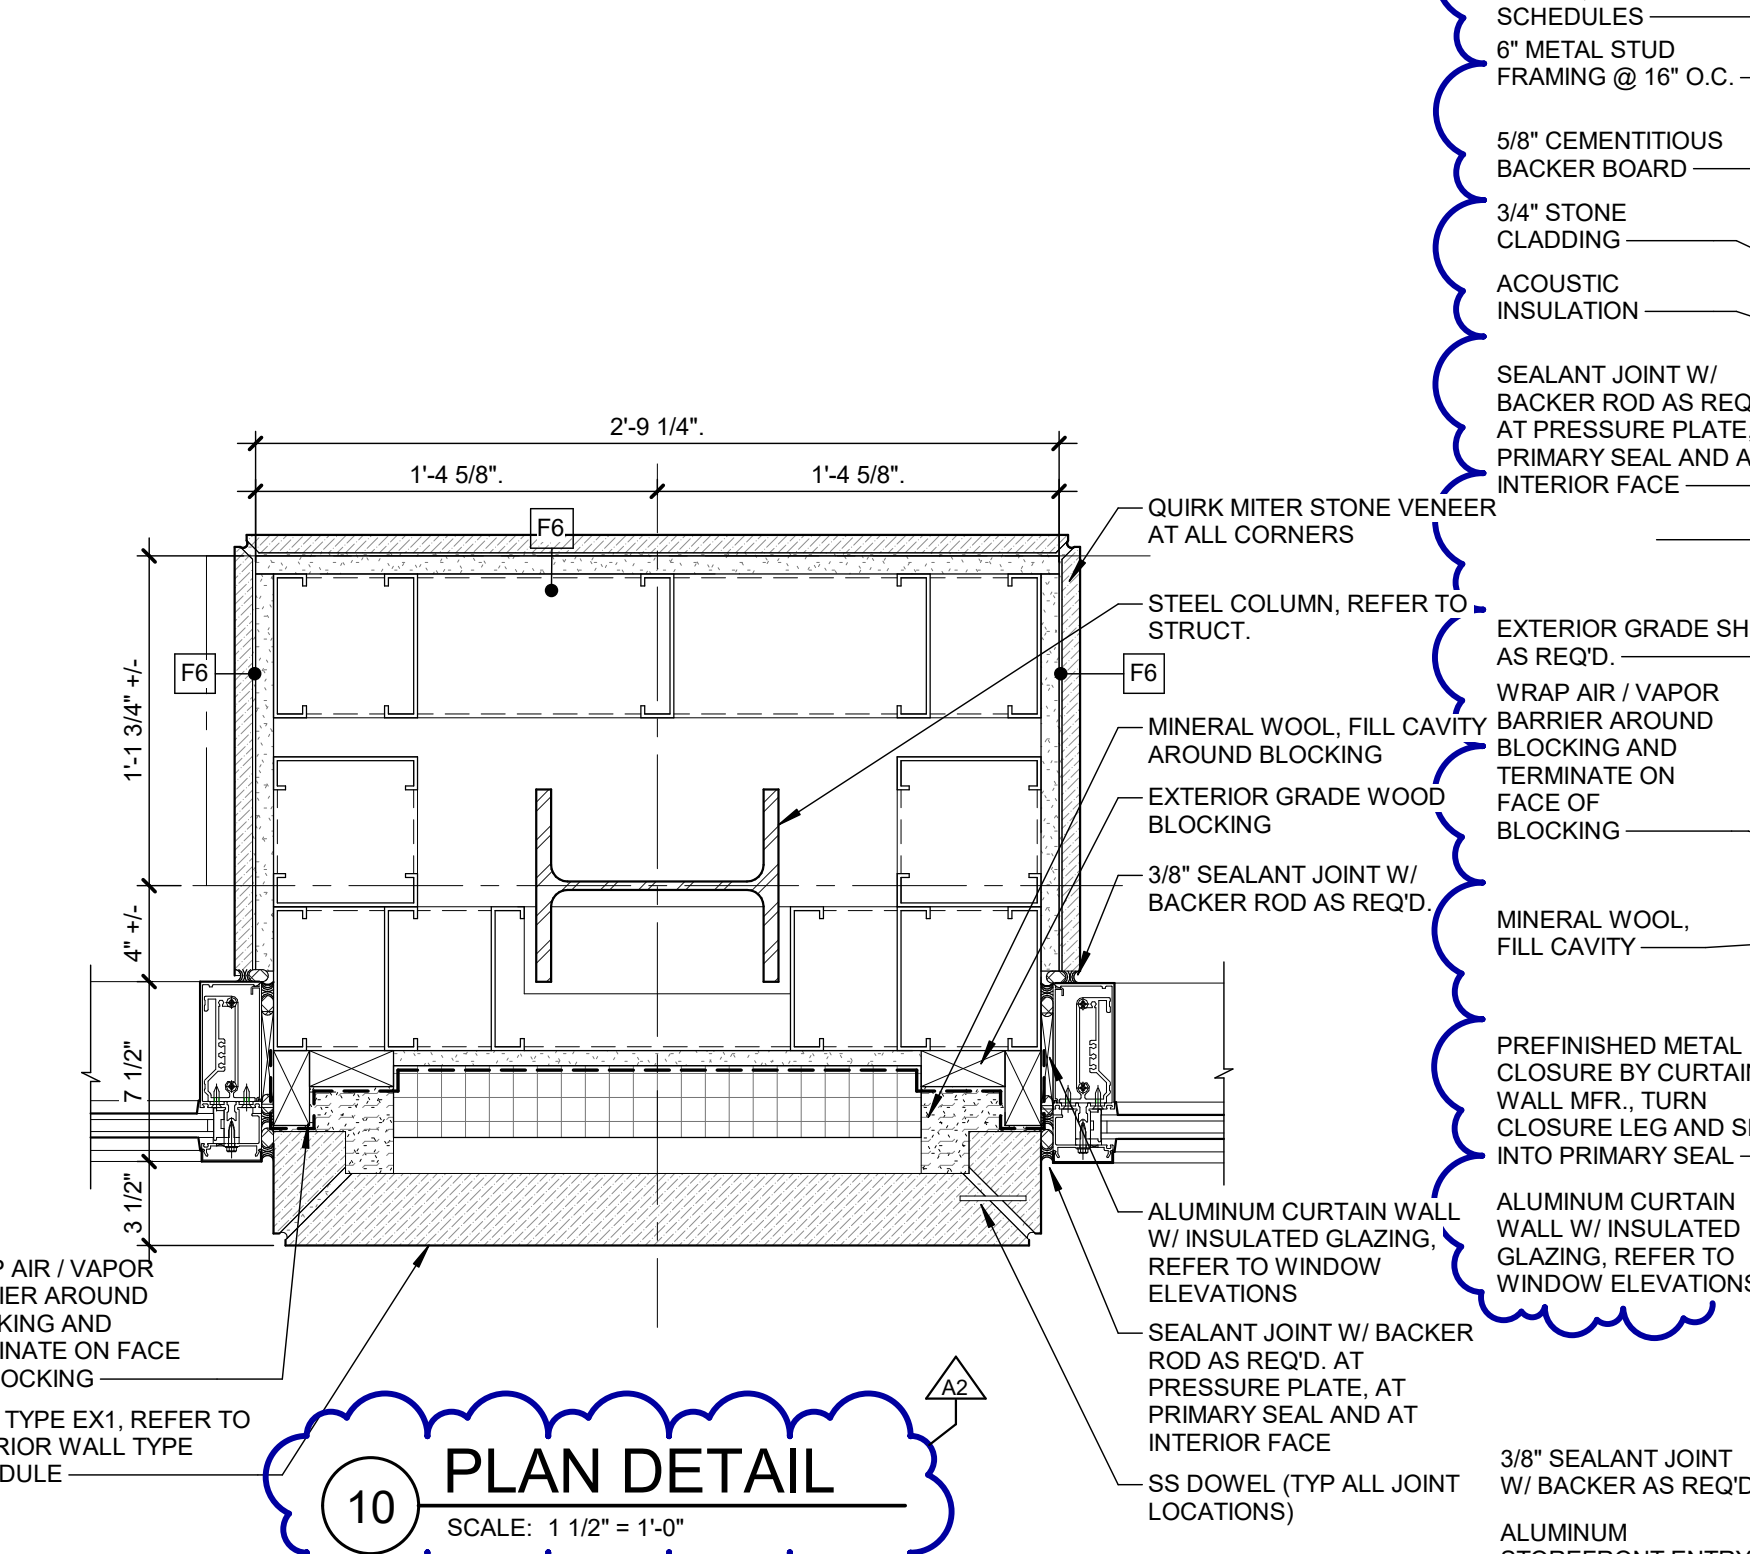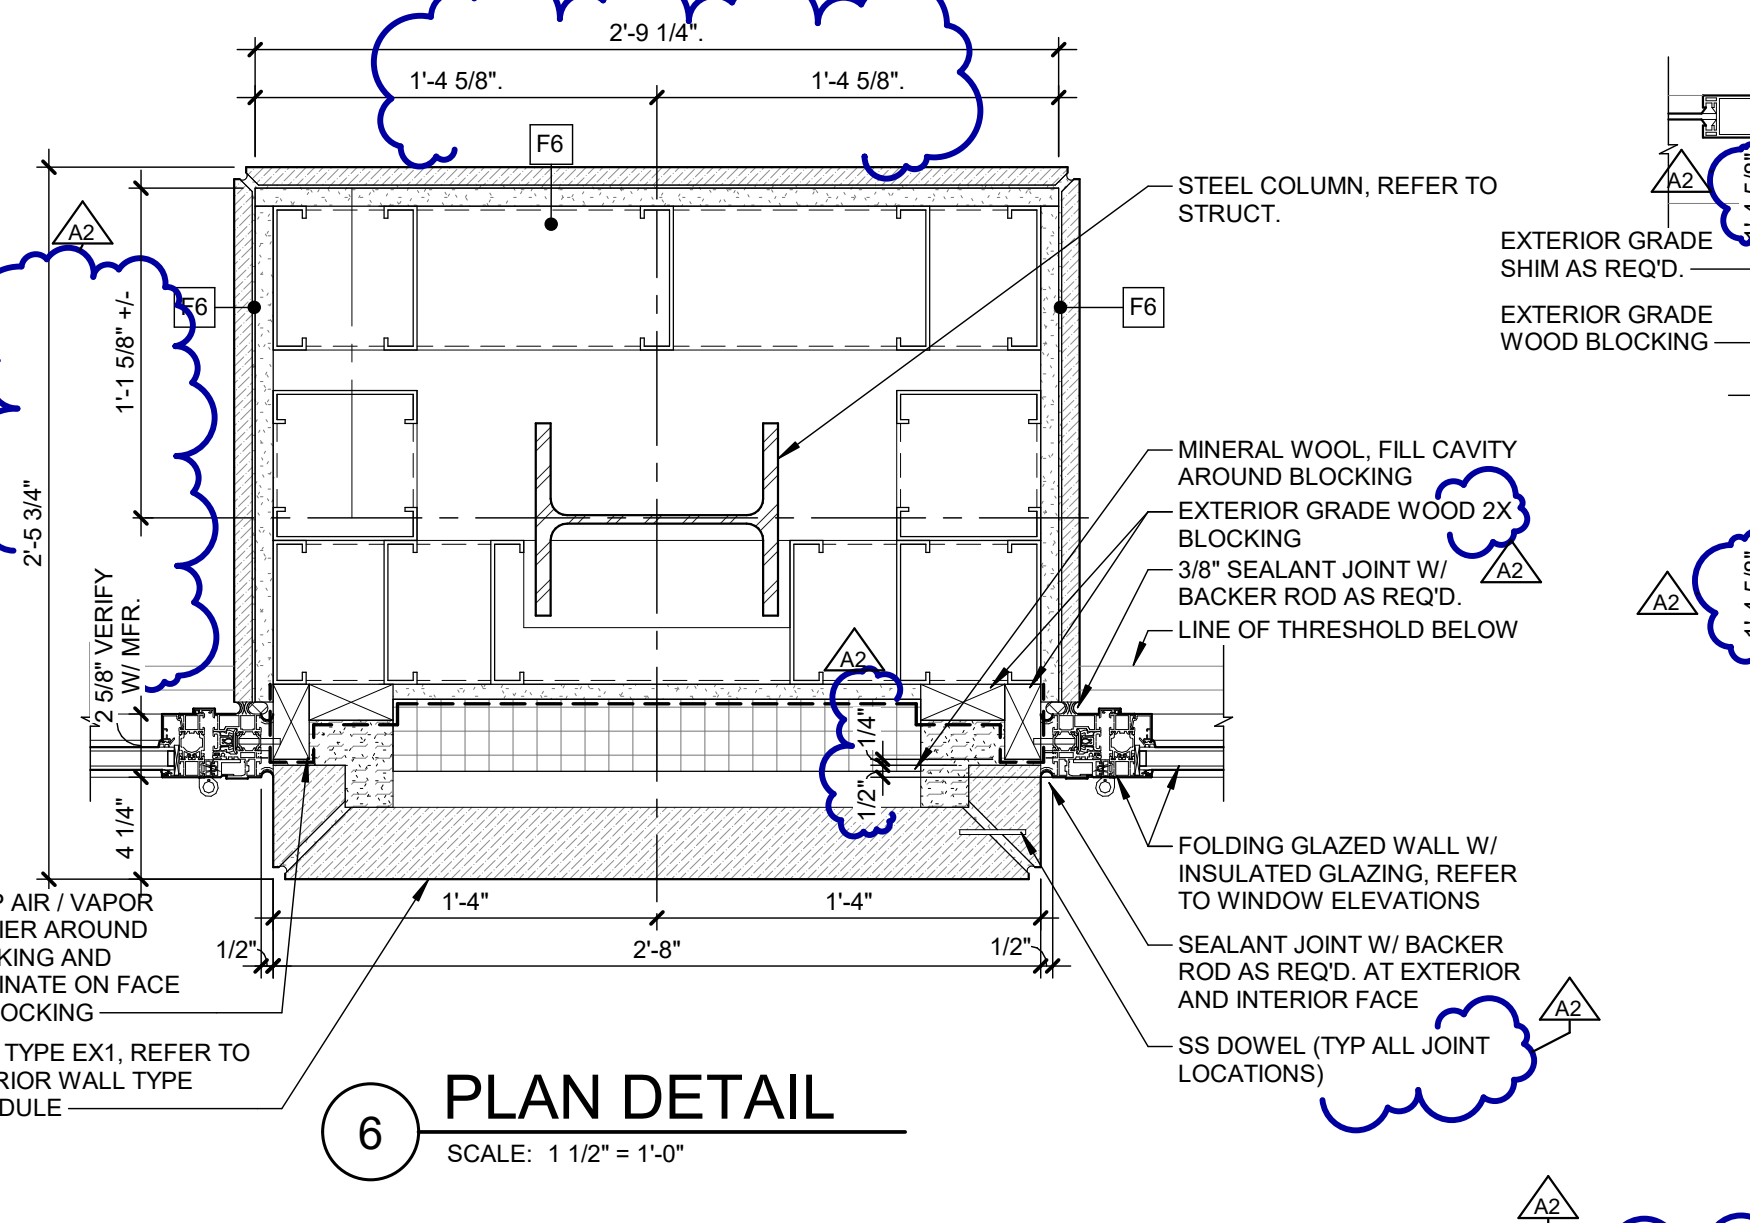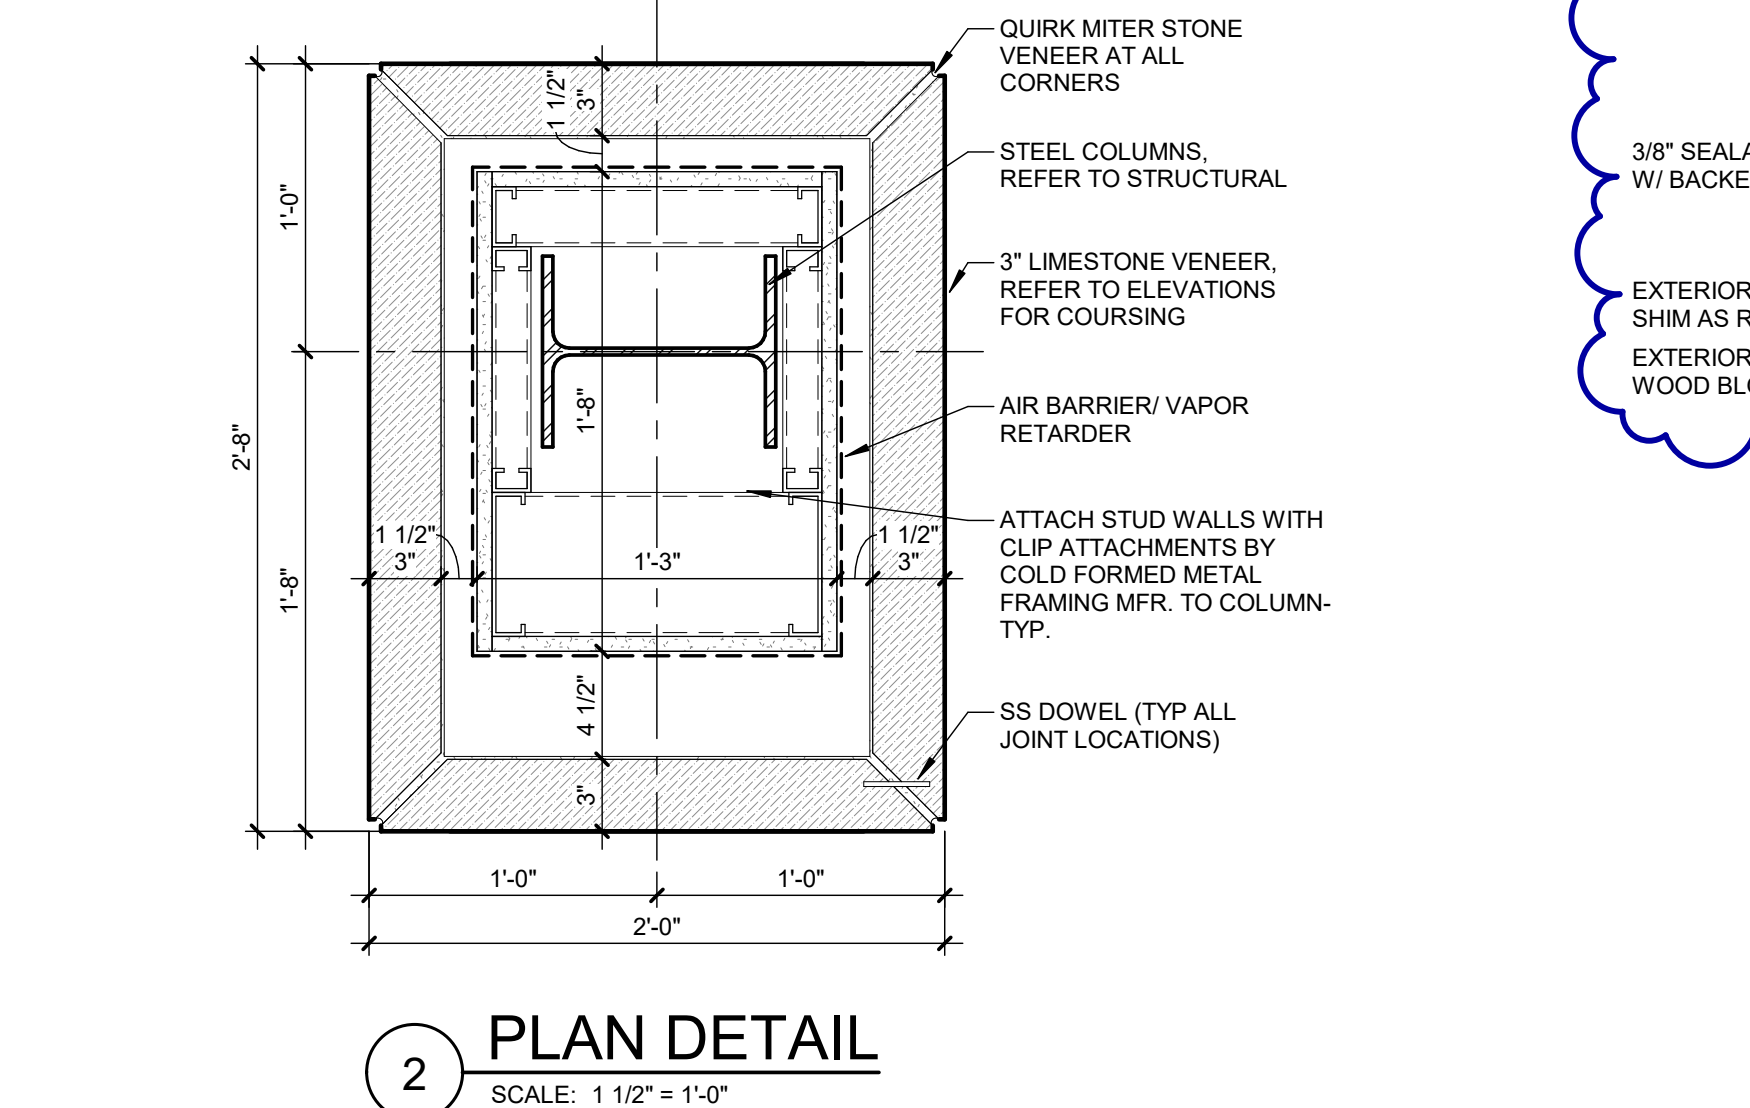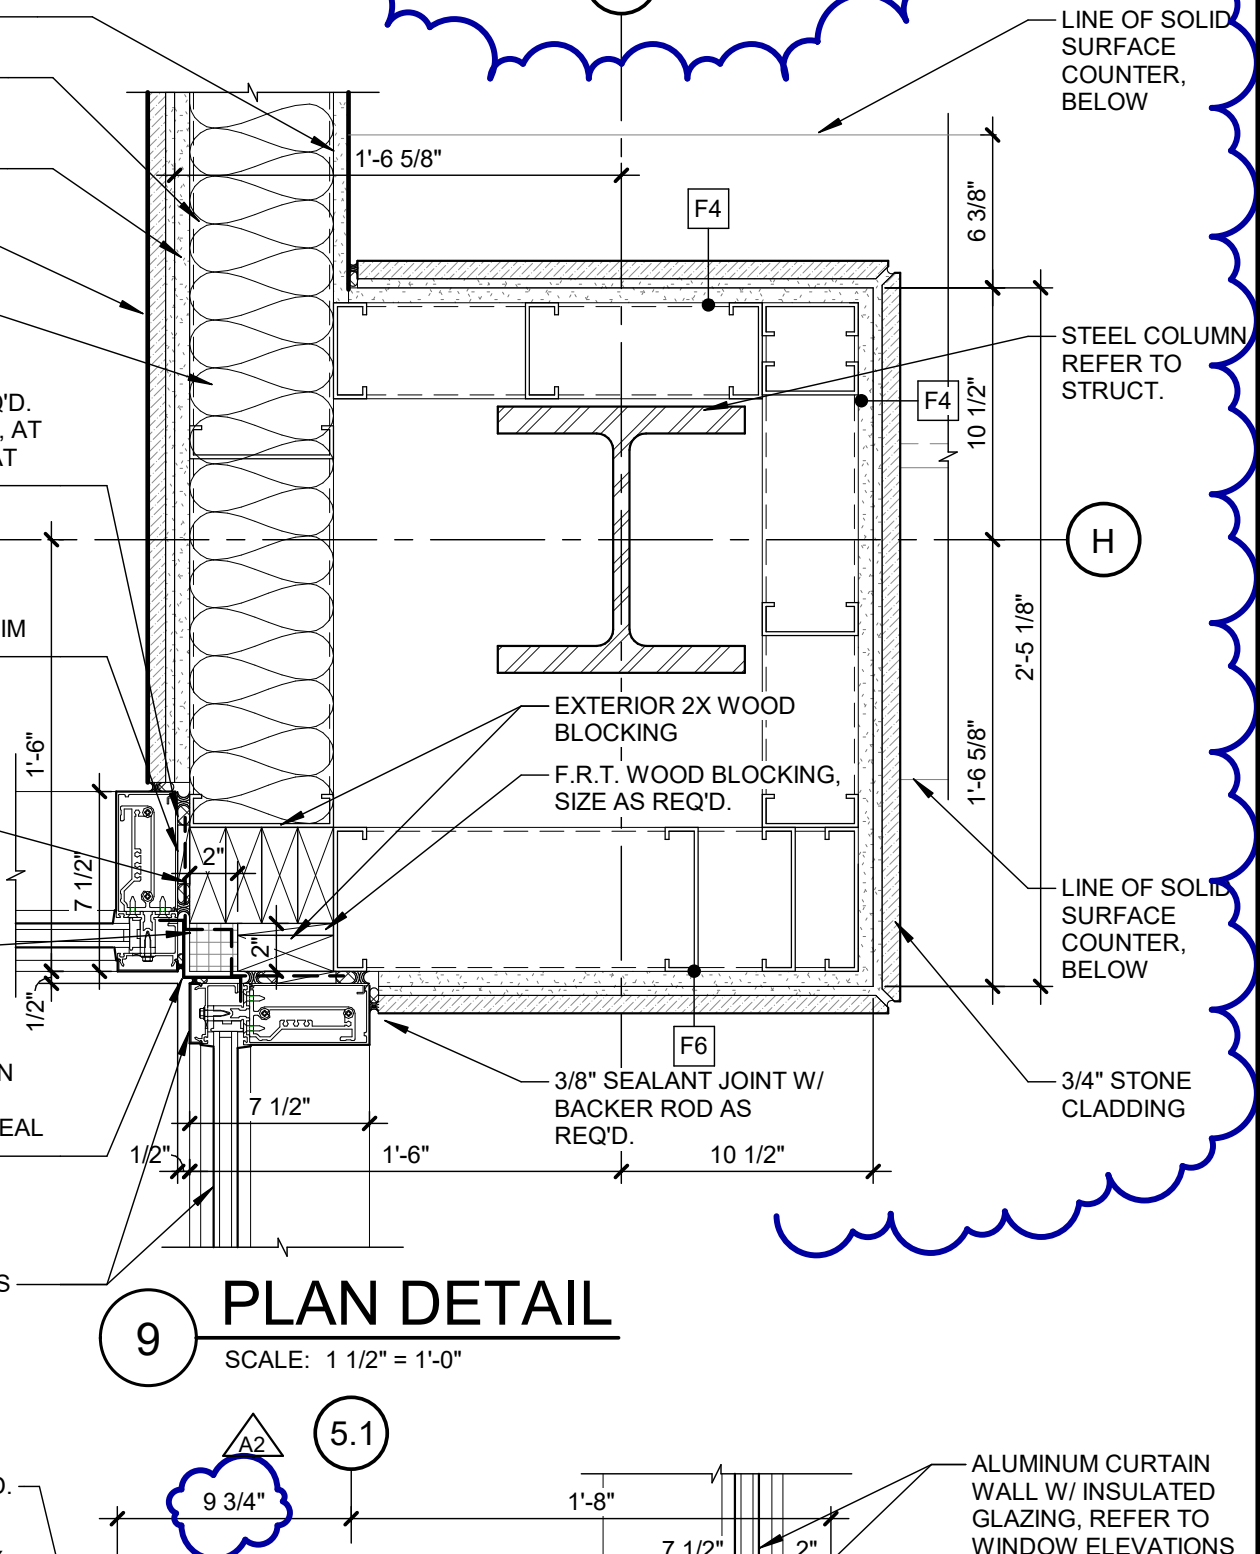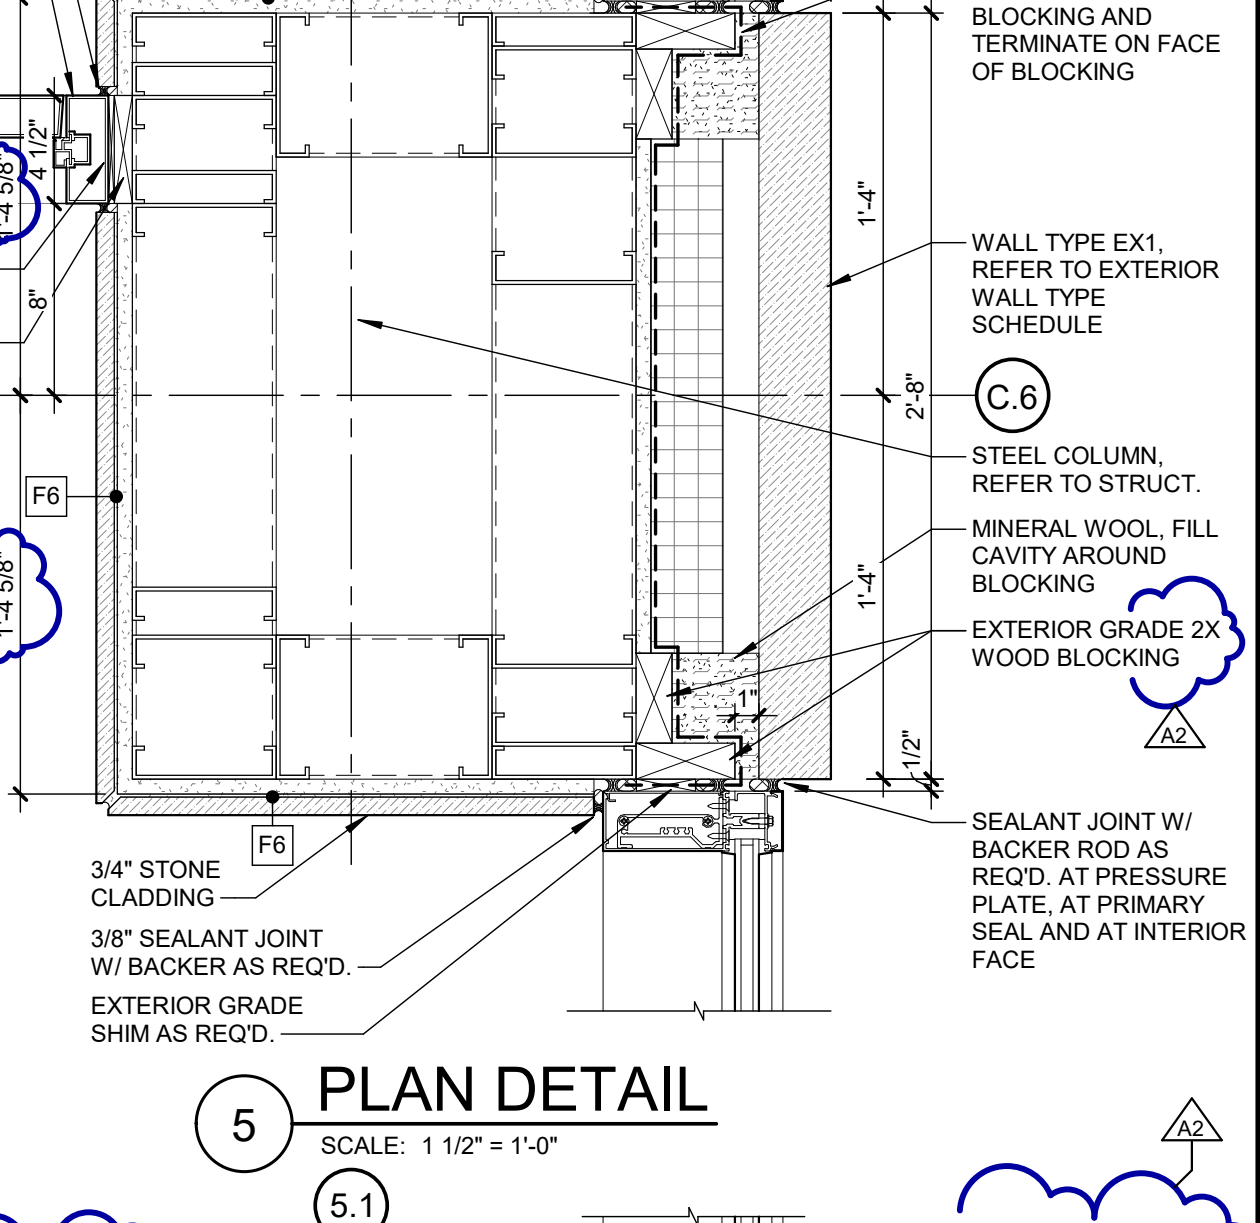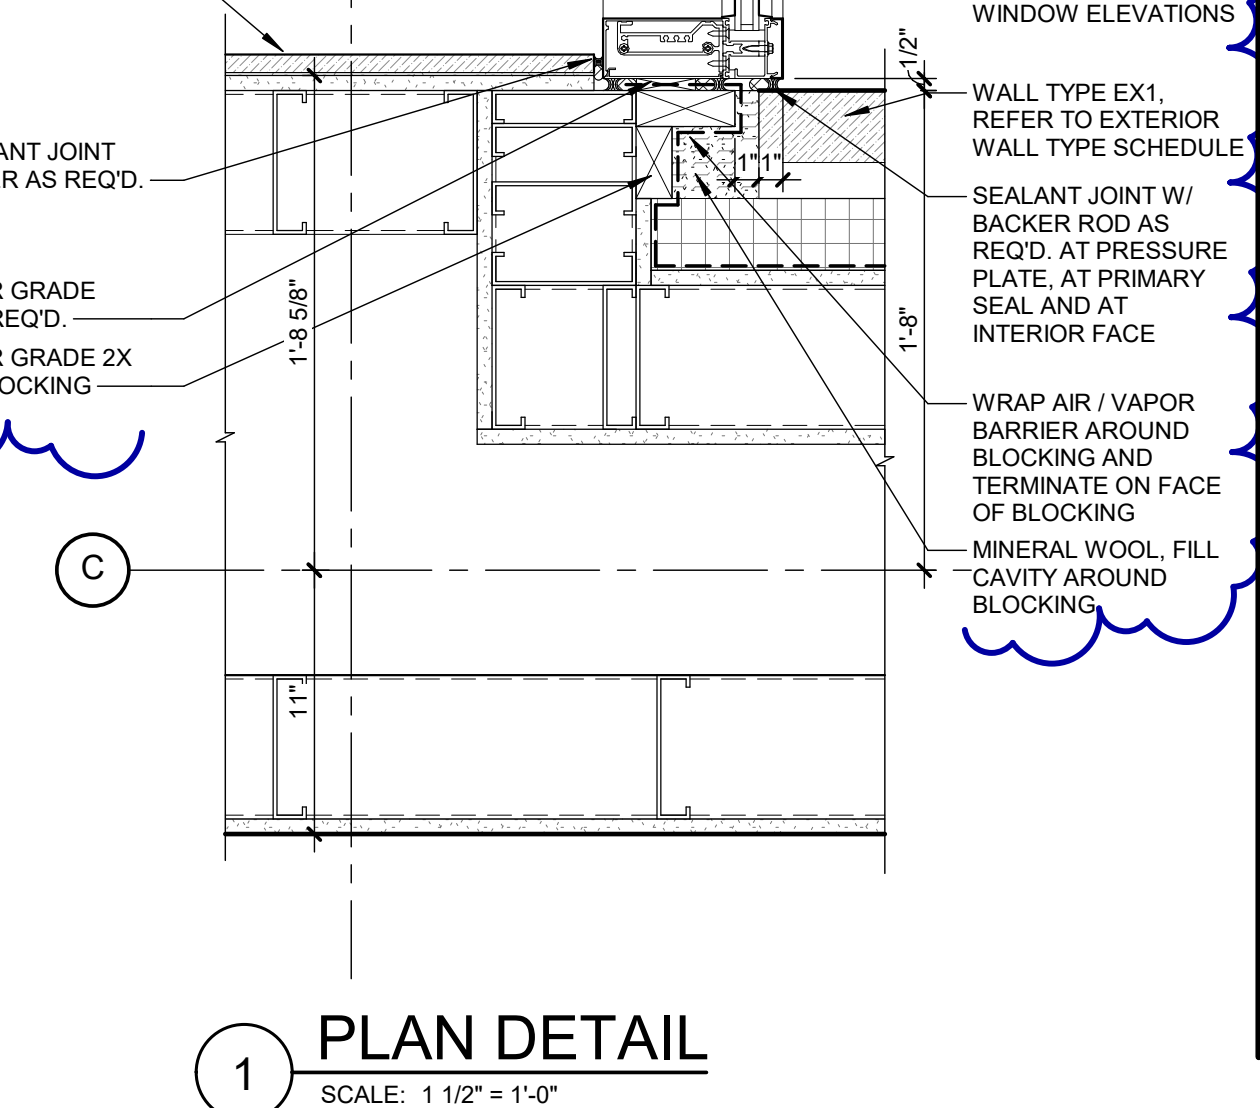

fishbeck

Engineers | Architects | Scientists | Constructors

Van Buren Charter Township

Van Buren Township, MI

The Lakeside Park

REVISIONS	
10/27/2026	A2 ADDENDUM NO. 2

10/12/2026	BIDS & PERMIT
09/21/2026	CD PEER REVIEW
09/09/2026	CD TEAM REVIEW
08/10/2026	CD 50% PROGRESS
08/22/2026	DD OWNER REVIEW
06/15/2026	DD OWNER REVIEW
06/08/2026	DD 90 % PROGRESS
05/18/2026	DD 50 % PROGRESS
02/23/2026	SD OWNER REVIEW
02/13/2026	SD PEER REVIEW
02/09/2026	SD PROGRESS REVIEW

Drawn By

Designer

Reviewer

Manager

NGEERS

LFINNEY

WLRAPSON

CKRETOVIC

Hard copy is intended to be 24"x36" when plotted. Scale(s) indicated and graphic quality may not be accurate for any other size.

PROJECT NO.


2500281

SHEET NO.


A502

©Copyright 2026


All Rights Reserved

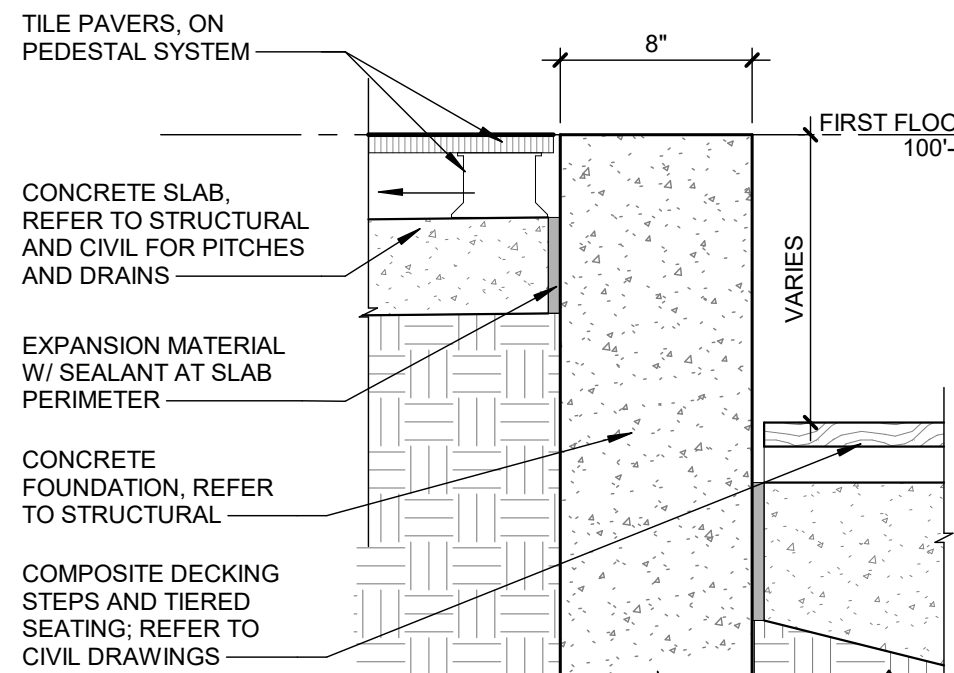


6 SECTION DETAIL
SCALE: 1 1/2" = 1'-0"

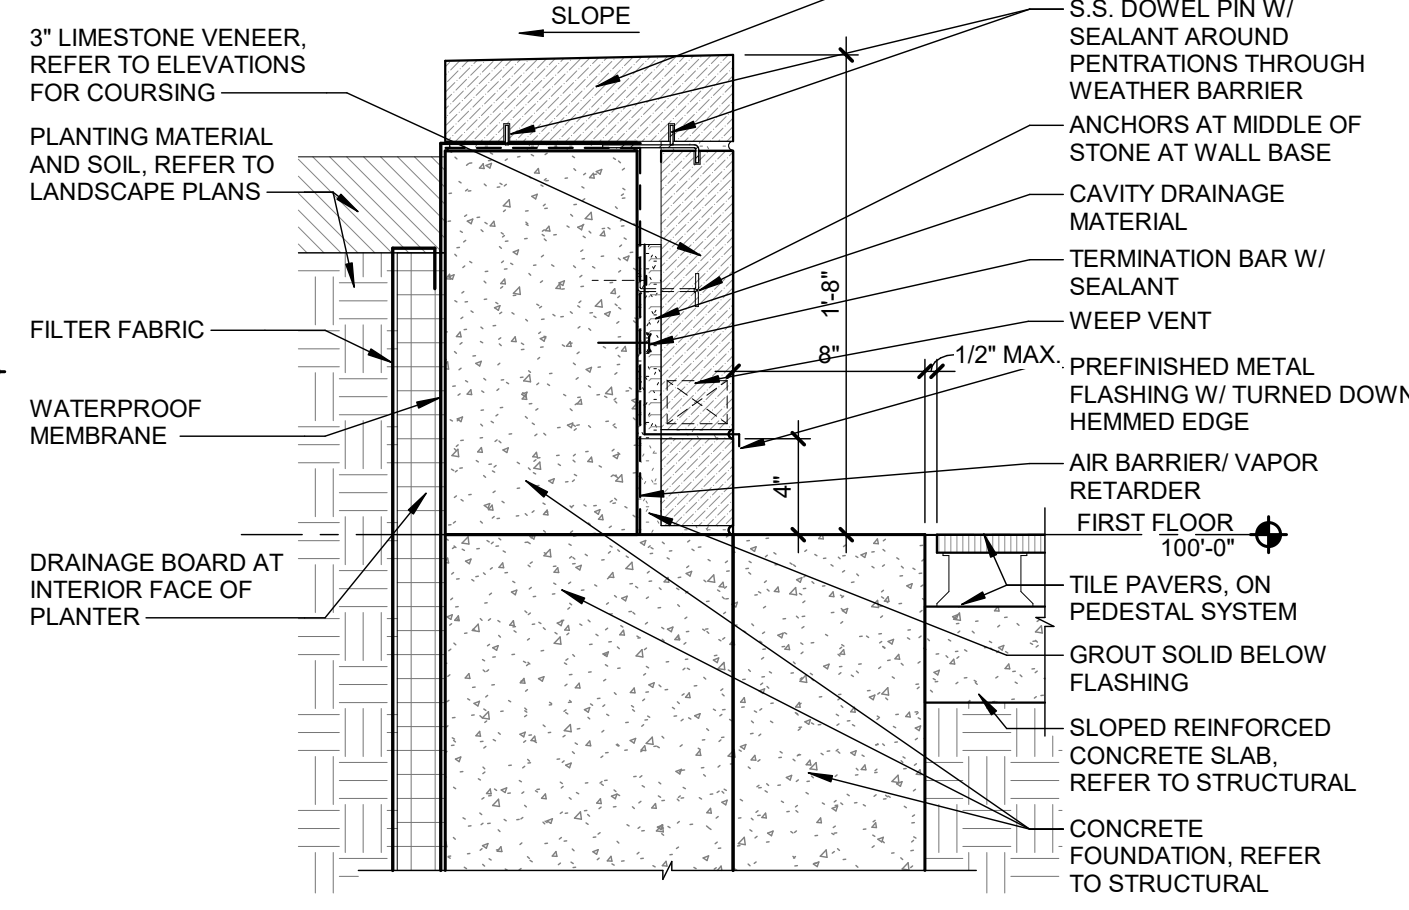


5 SECTION DETAIL
SCALE: 1 1/2" = 1'-0"

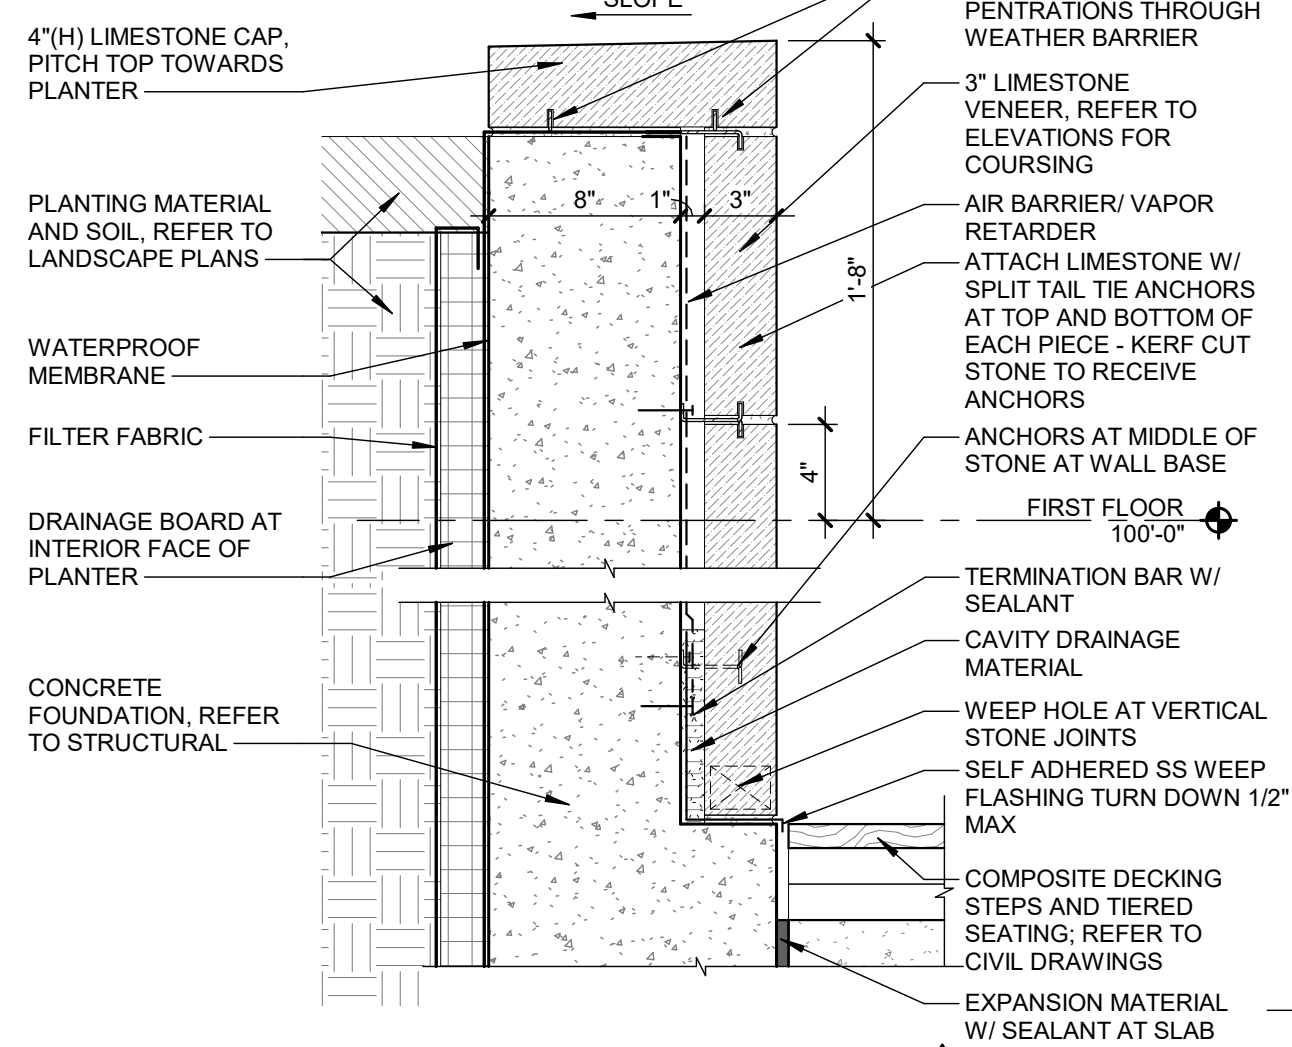

4 SECTION DETAIL
SCALE: 1 1/2" = 1'-0"

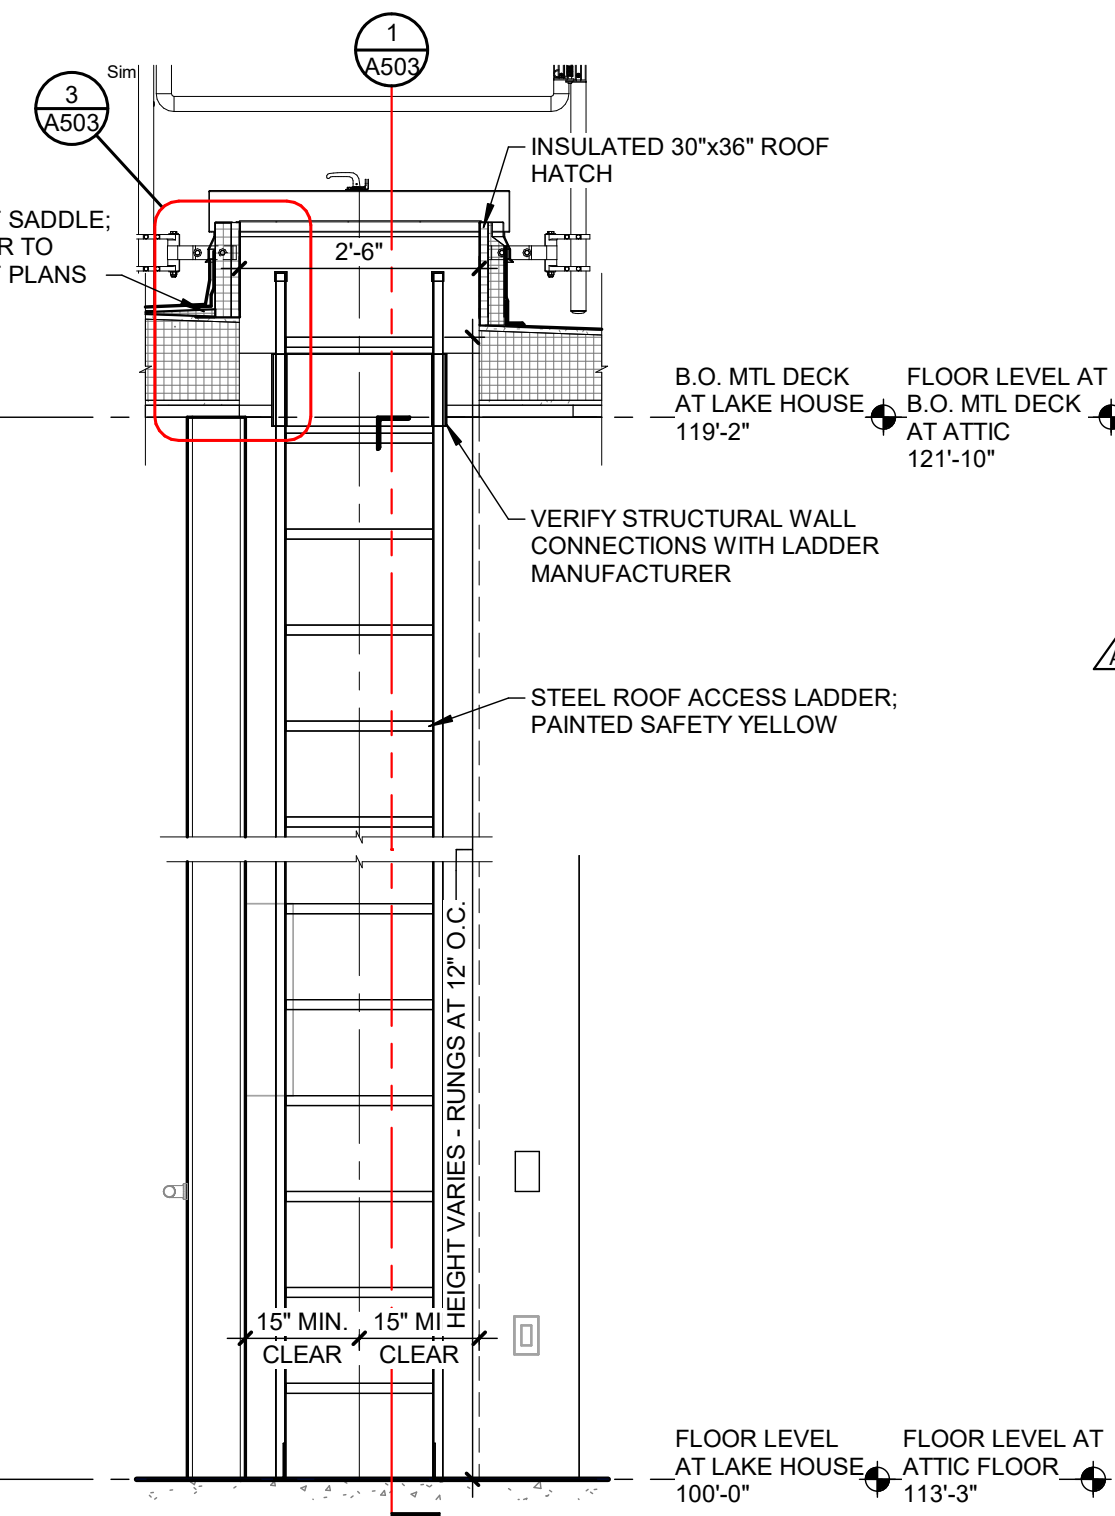

2 LADDER ELEVATION
SCALE: 1/2" = 1'-0"

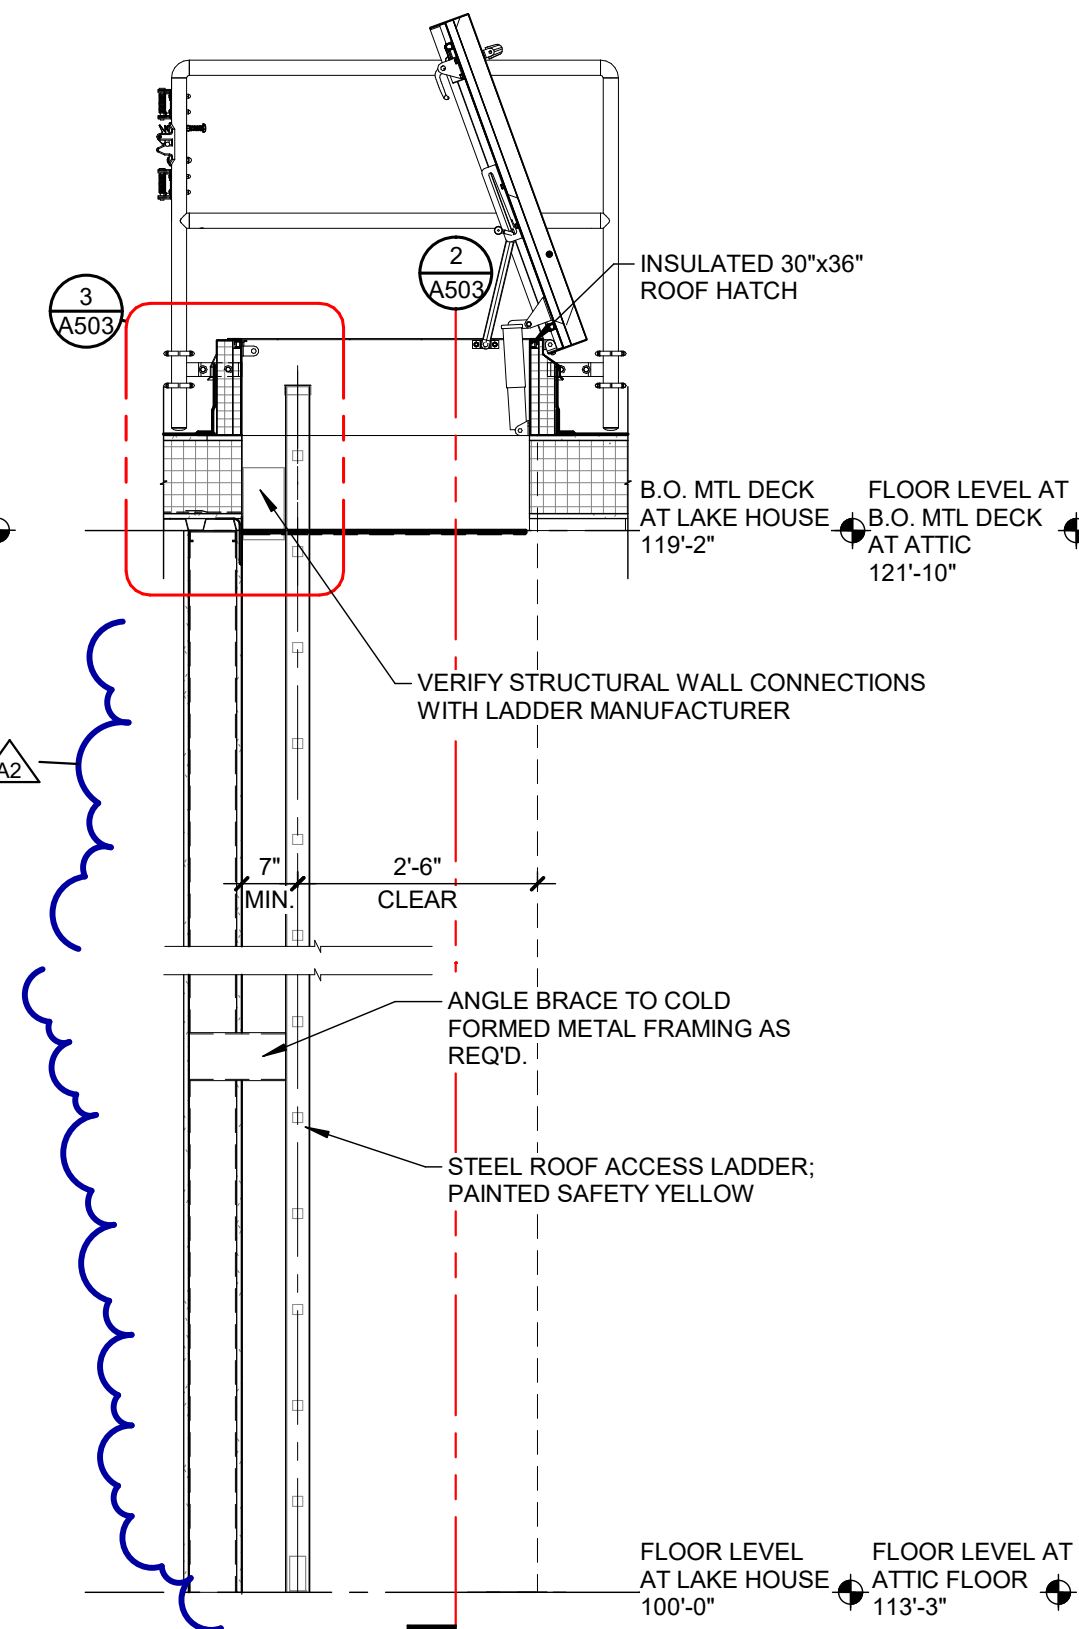


1 LADDER SECTION
SCALE: 1/2" = 1'-0"

3 LADDER SECTION DETAIL
SCALE: 1 1/2" = 1'-0"


7 SECTION DETAIL
SCALE: 1 1/2" = 1'-0"

8 SECTION DETAIL
SCALE: 1 1/2" = 1'-0"


9 SECTION DETAIL
SCALE: 1 1/2" = 1'-0"

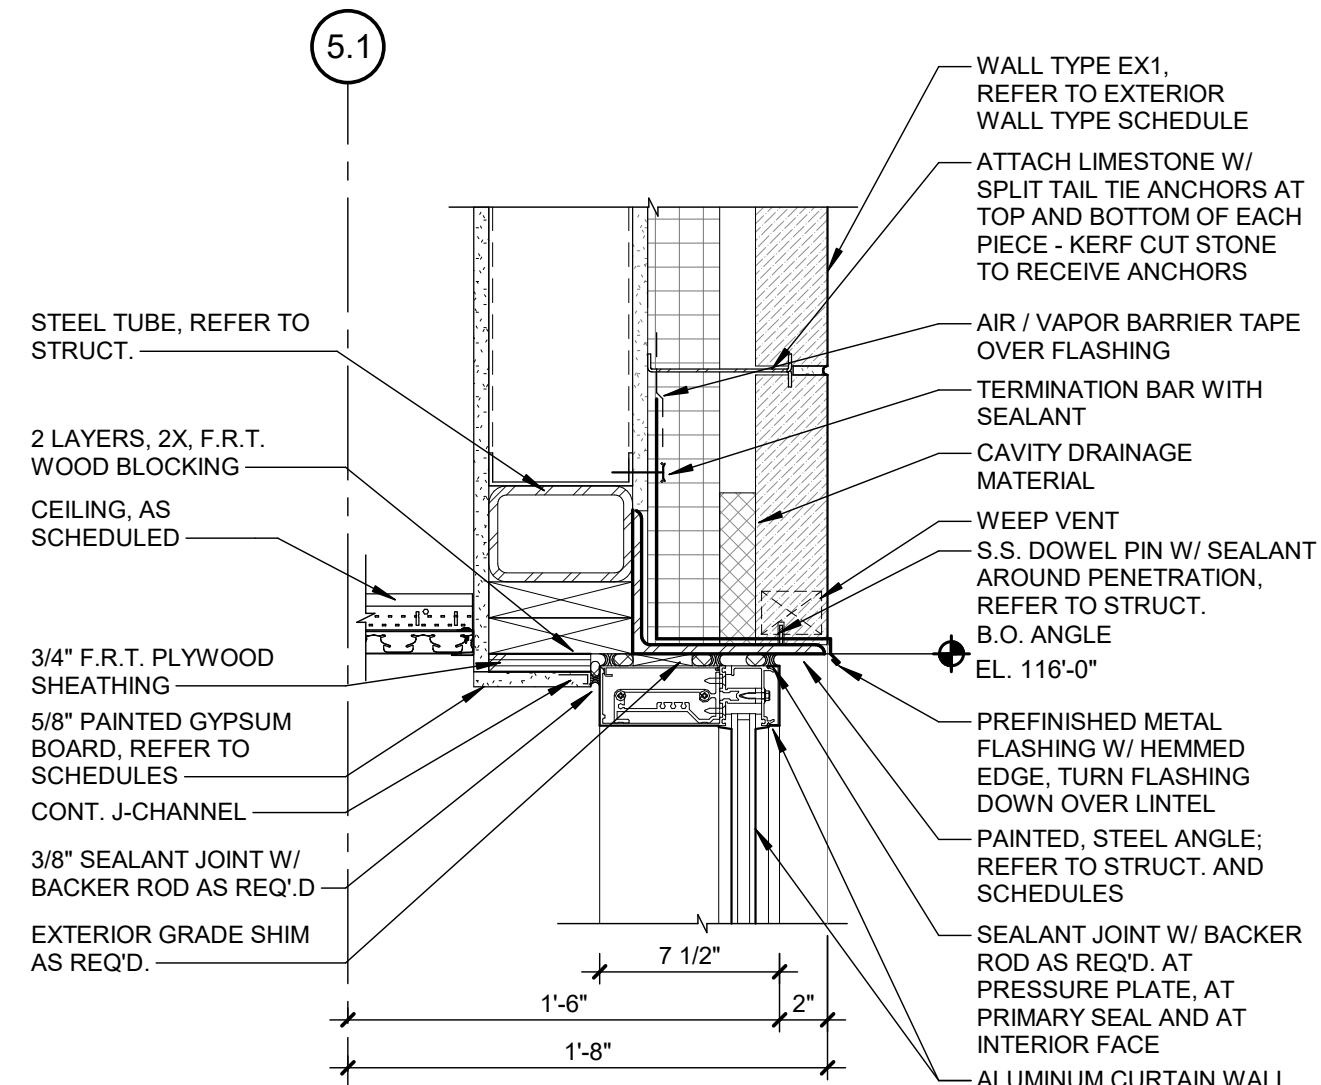


12 SECTION DETAIL
SCALE: 1 1/2" = 1'-0"

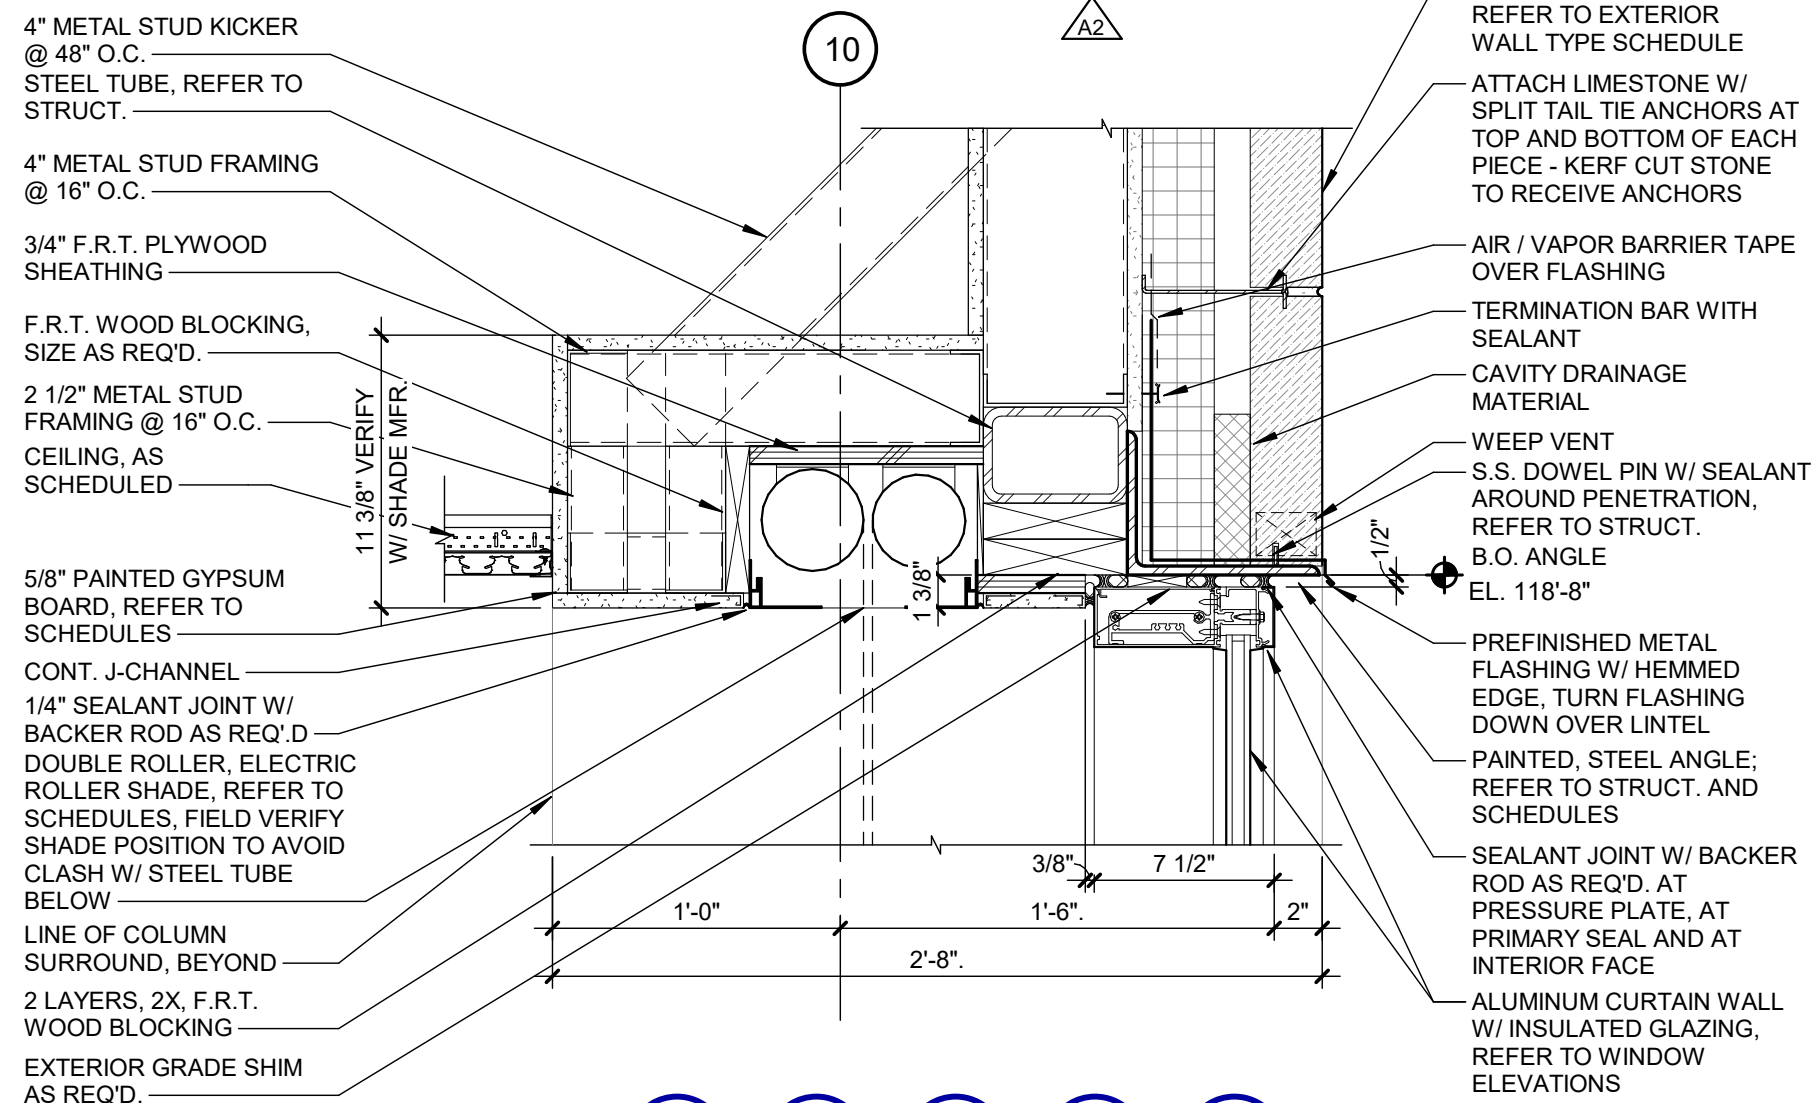

11 SECTION DETAIL
SCALE: 1 1/2" = 1'-0"

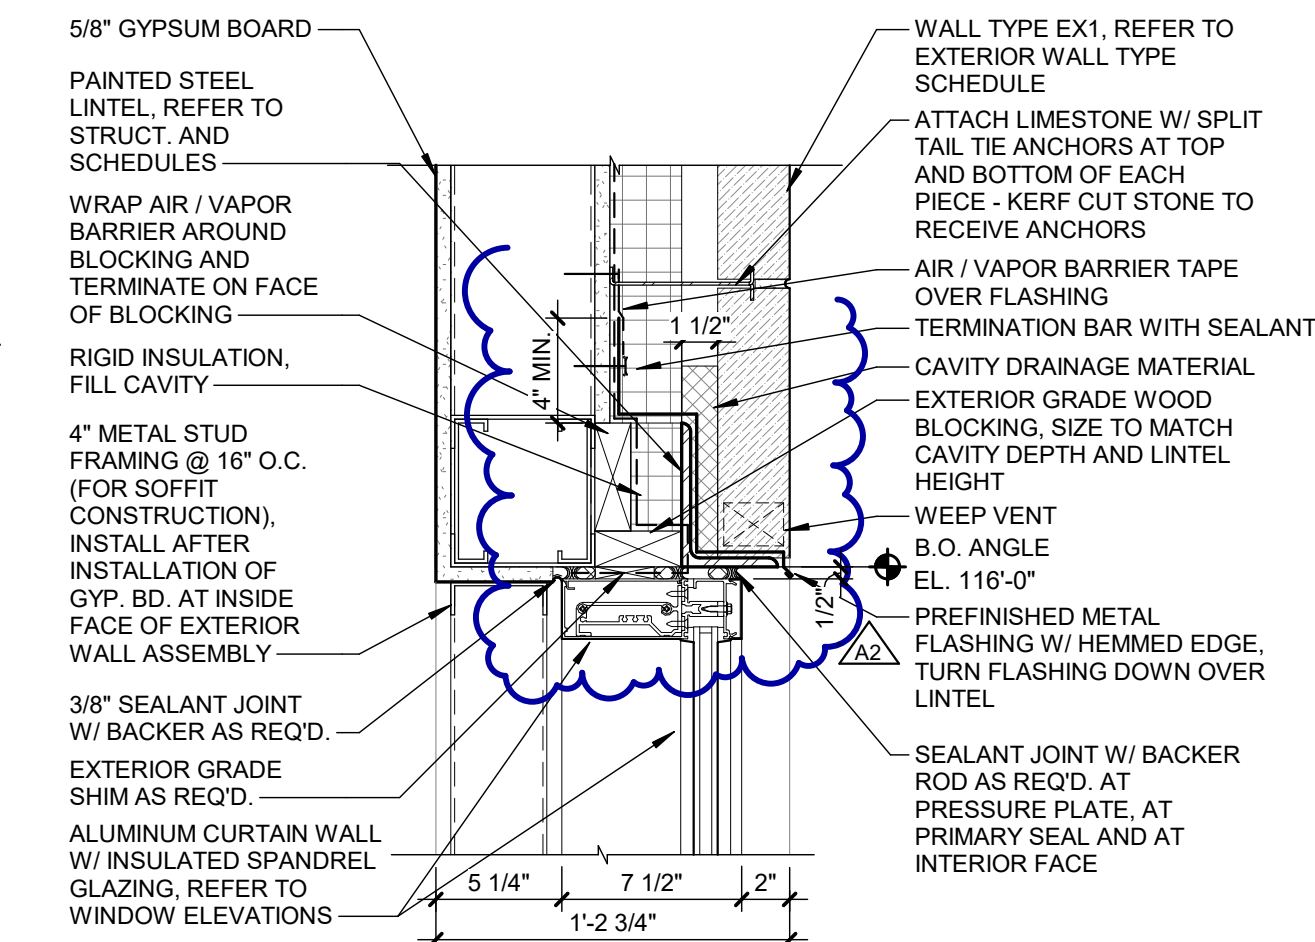

10 SECTION DETAIL
SCALE: 1 1/2" = 1'-0"

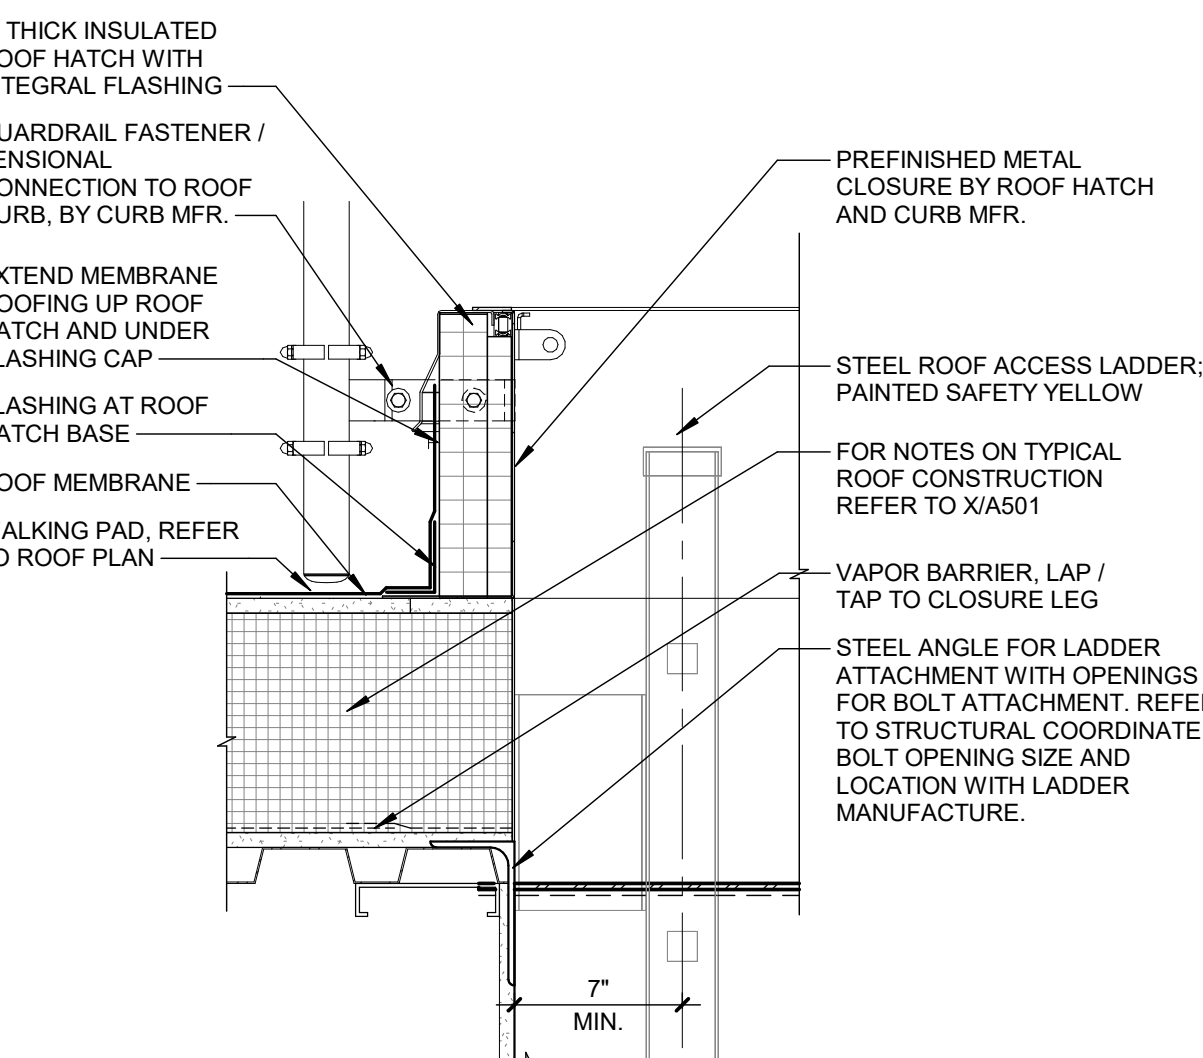

REVISIONS		
10/27/2026	A2	ADDENDUM NO. 2

10/12/2026	BIDS & PERMIT
09/21/2026	CD PEER REVIEW
09/09/2026	CD TEAM REVIEW
08/10/2026	CD 50% PROGRESS
08/22/2026	DD OWNER REVIEW
06/15/2026	DD PEER REVIEW
06/08/2026	DD 90% PROGRESS
05/18/2026	DD 90% PROGRESS
02/23/2026	SD OWNER REVIEW
02/13/2026	SD PEER REVIEW
02/09/2026	SD PROGRESS REVIEW

Drawn By NGEERS
Designer LFINNEY
Reviewer WLAPSON
Manager CKRETOVIC

Hard copy is intended to be 24"x36" when plotted. Scale(s) indicated and graphic quality may not be accurate for any other size.

PROJECT NO.
2500281
SHEET NO.

A503

Van Buren Charter Township

Van Buren Township, MI

The Lakeside Park

fishbeck
Engineers | Architects | Scientists | Constructors

REVISIONS		
10/27/2026	A2	ADDENDUM NO. 2

10/12/2026	BIDS & PERMIT
09/21/2026	CD PEER REVIEW
09/09/2026	CD TEAM REVIEW
08/10/2026	CD 50% PROGRESS
06/22/2026	DD OWNER REVIEW
06/15/2026	DD PEER REVIEW
06/08/2026	DD 90 % PROGRESS
05/18/2026	DD 50 % PROGRESS
02/23/2026	SD OWNER REVIEW
02/13/2026	SD PEER REVIEW
02/09/2026	SD PROGRESS REVIEW

Drawn By	IOLKHOVESKA
Designer	LFINNEY
Reviewer	WLRAPSON
Manager	CKRETOVIC


Hard copy is intended to be 24"x36" when plotted. Scale(s) indicated and graphic quality may not be accurate for any other size.

PROJECT NO.
2500281


SHEET NO.

A521


©Copyright 2026
All Rights Reserved

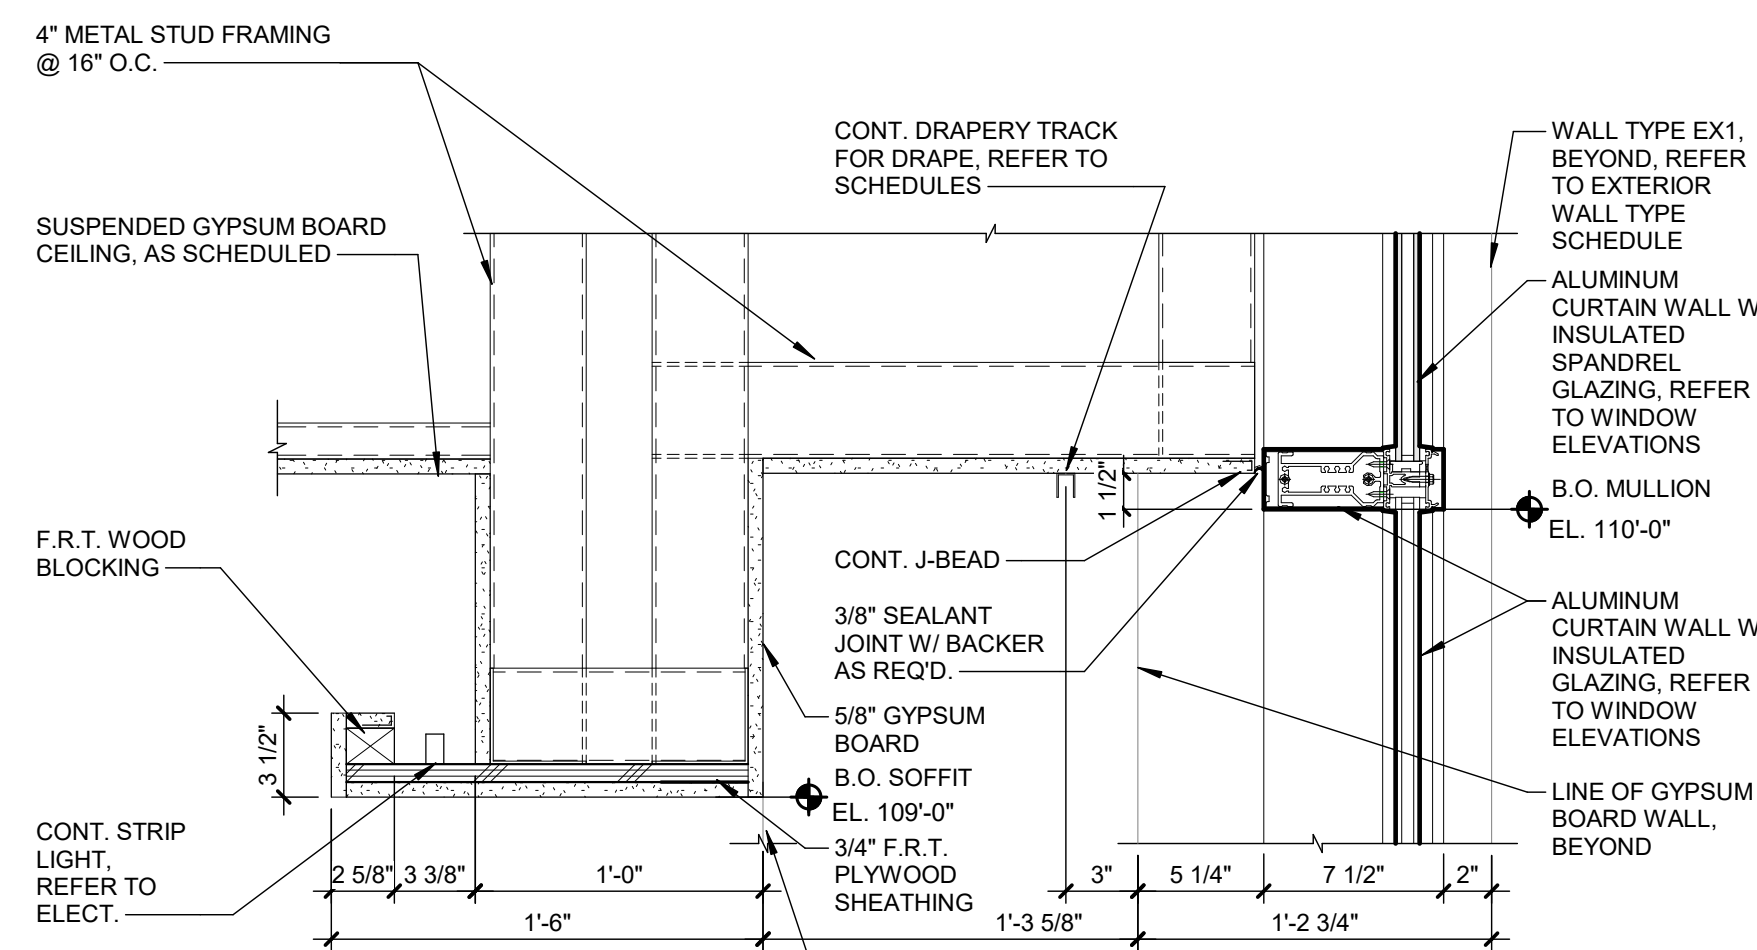


9 SECTION DETAIL
SCALE: 1 1/2" = 1'-0"

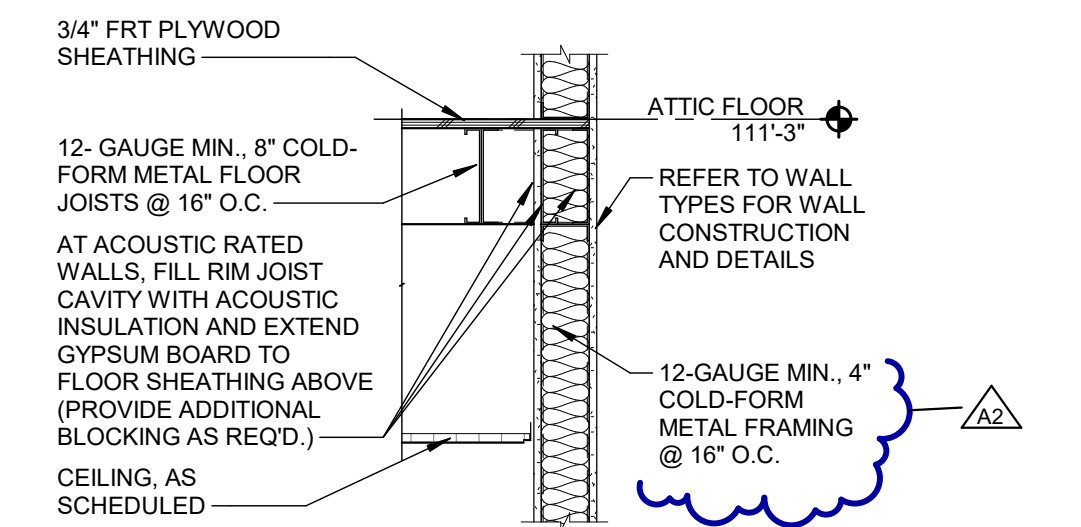


10 SECTION DETAIL
SCALE: 3/4" = 1'-0"

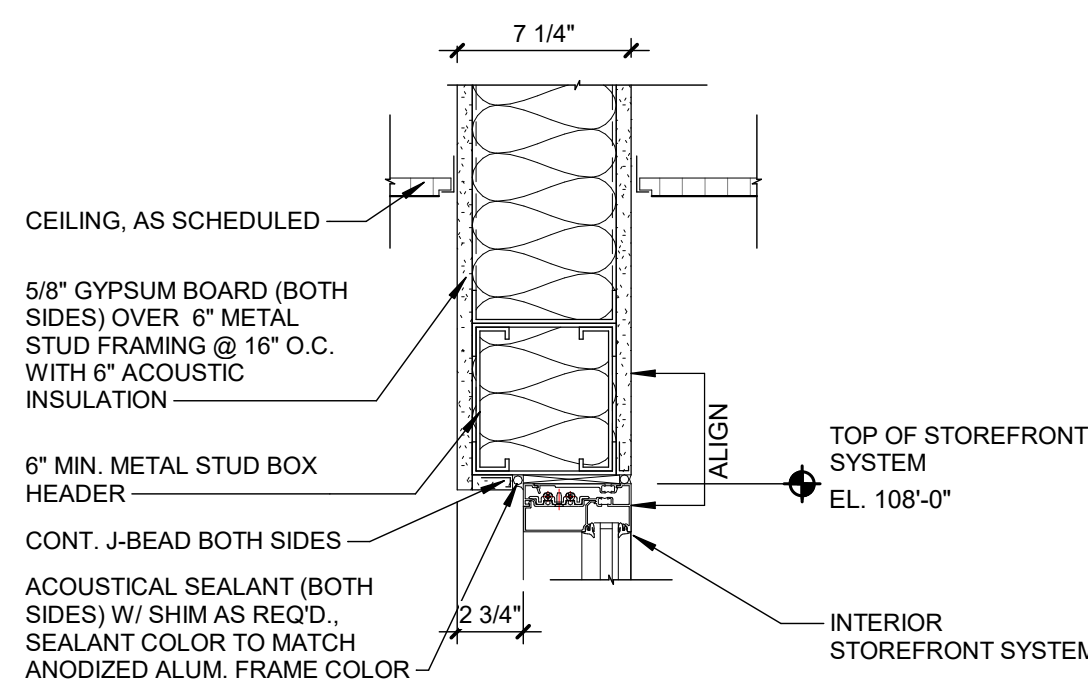


8 SECTION DETAIL
SCALE: 1 1/2" = 1'-0"

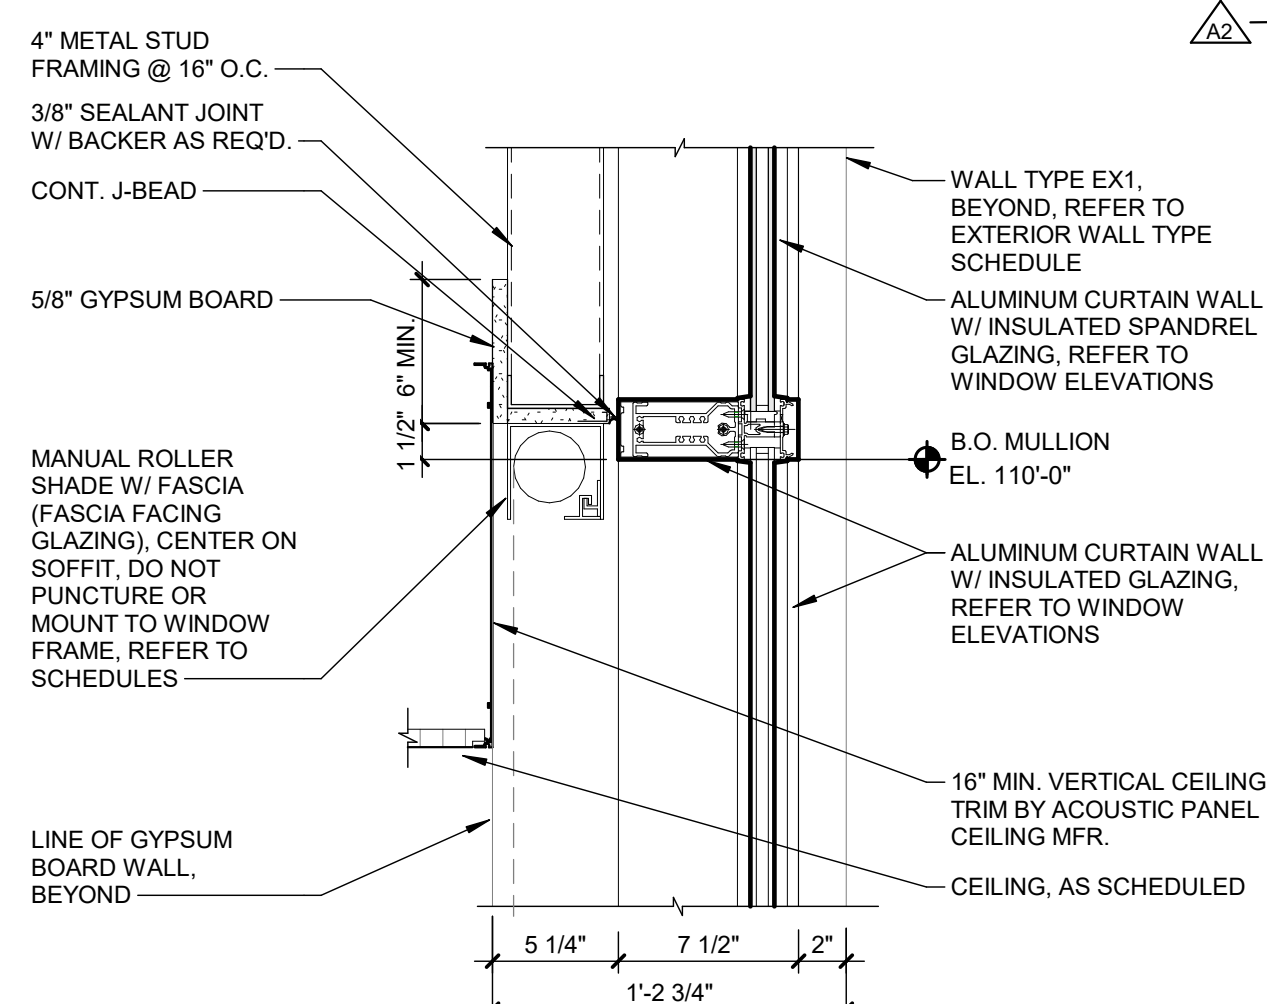


5 SECTION DETAIL
SCALE: 1 1/2" = 1'-0"

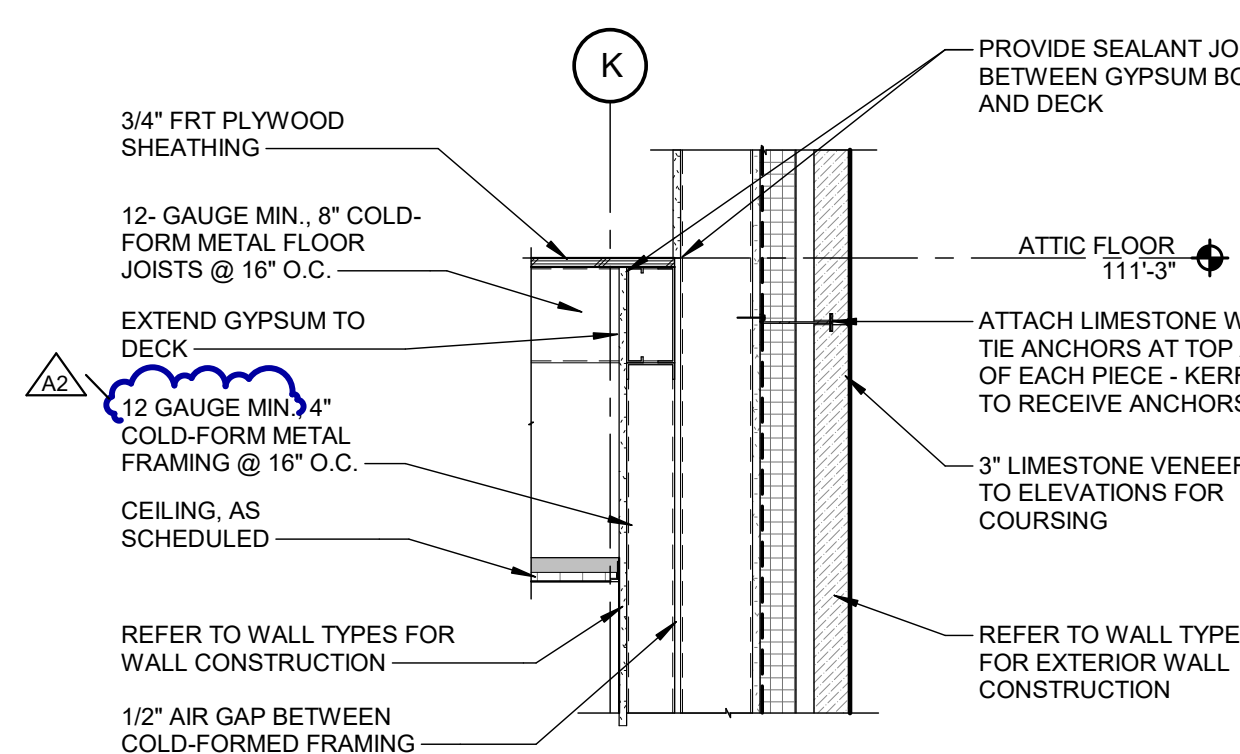


2 SECTION DETAIL
SCALE: 3/4" = 1'-0"

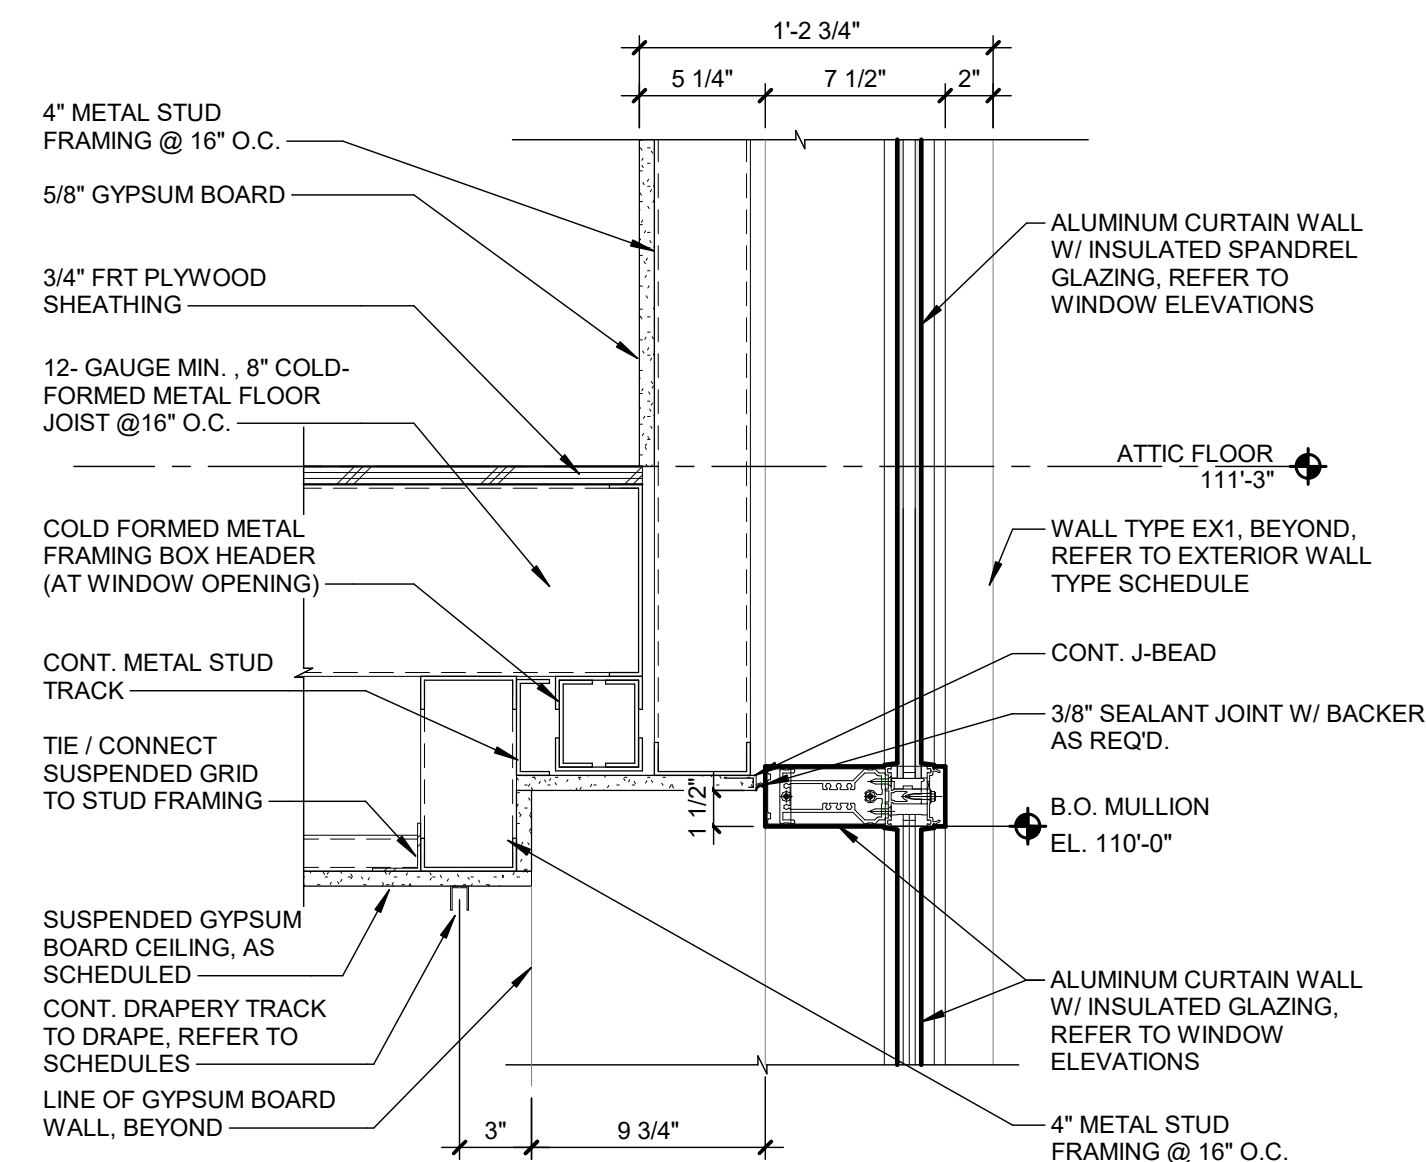

7 SECTION DETAIL
SCALE: 1 1/2" = 1'-0"

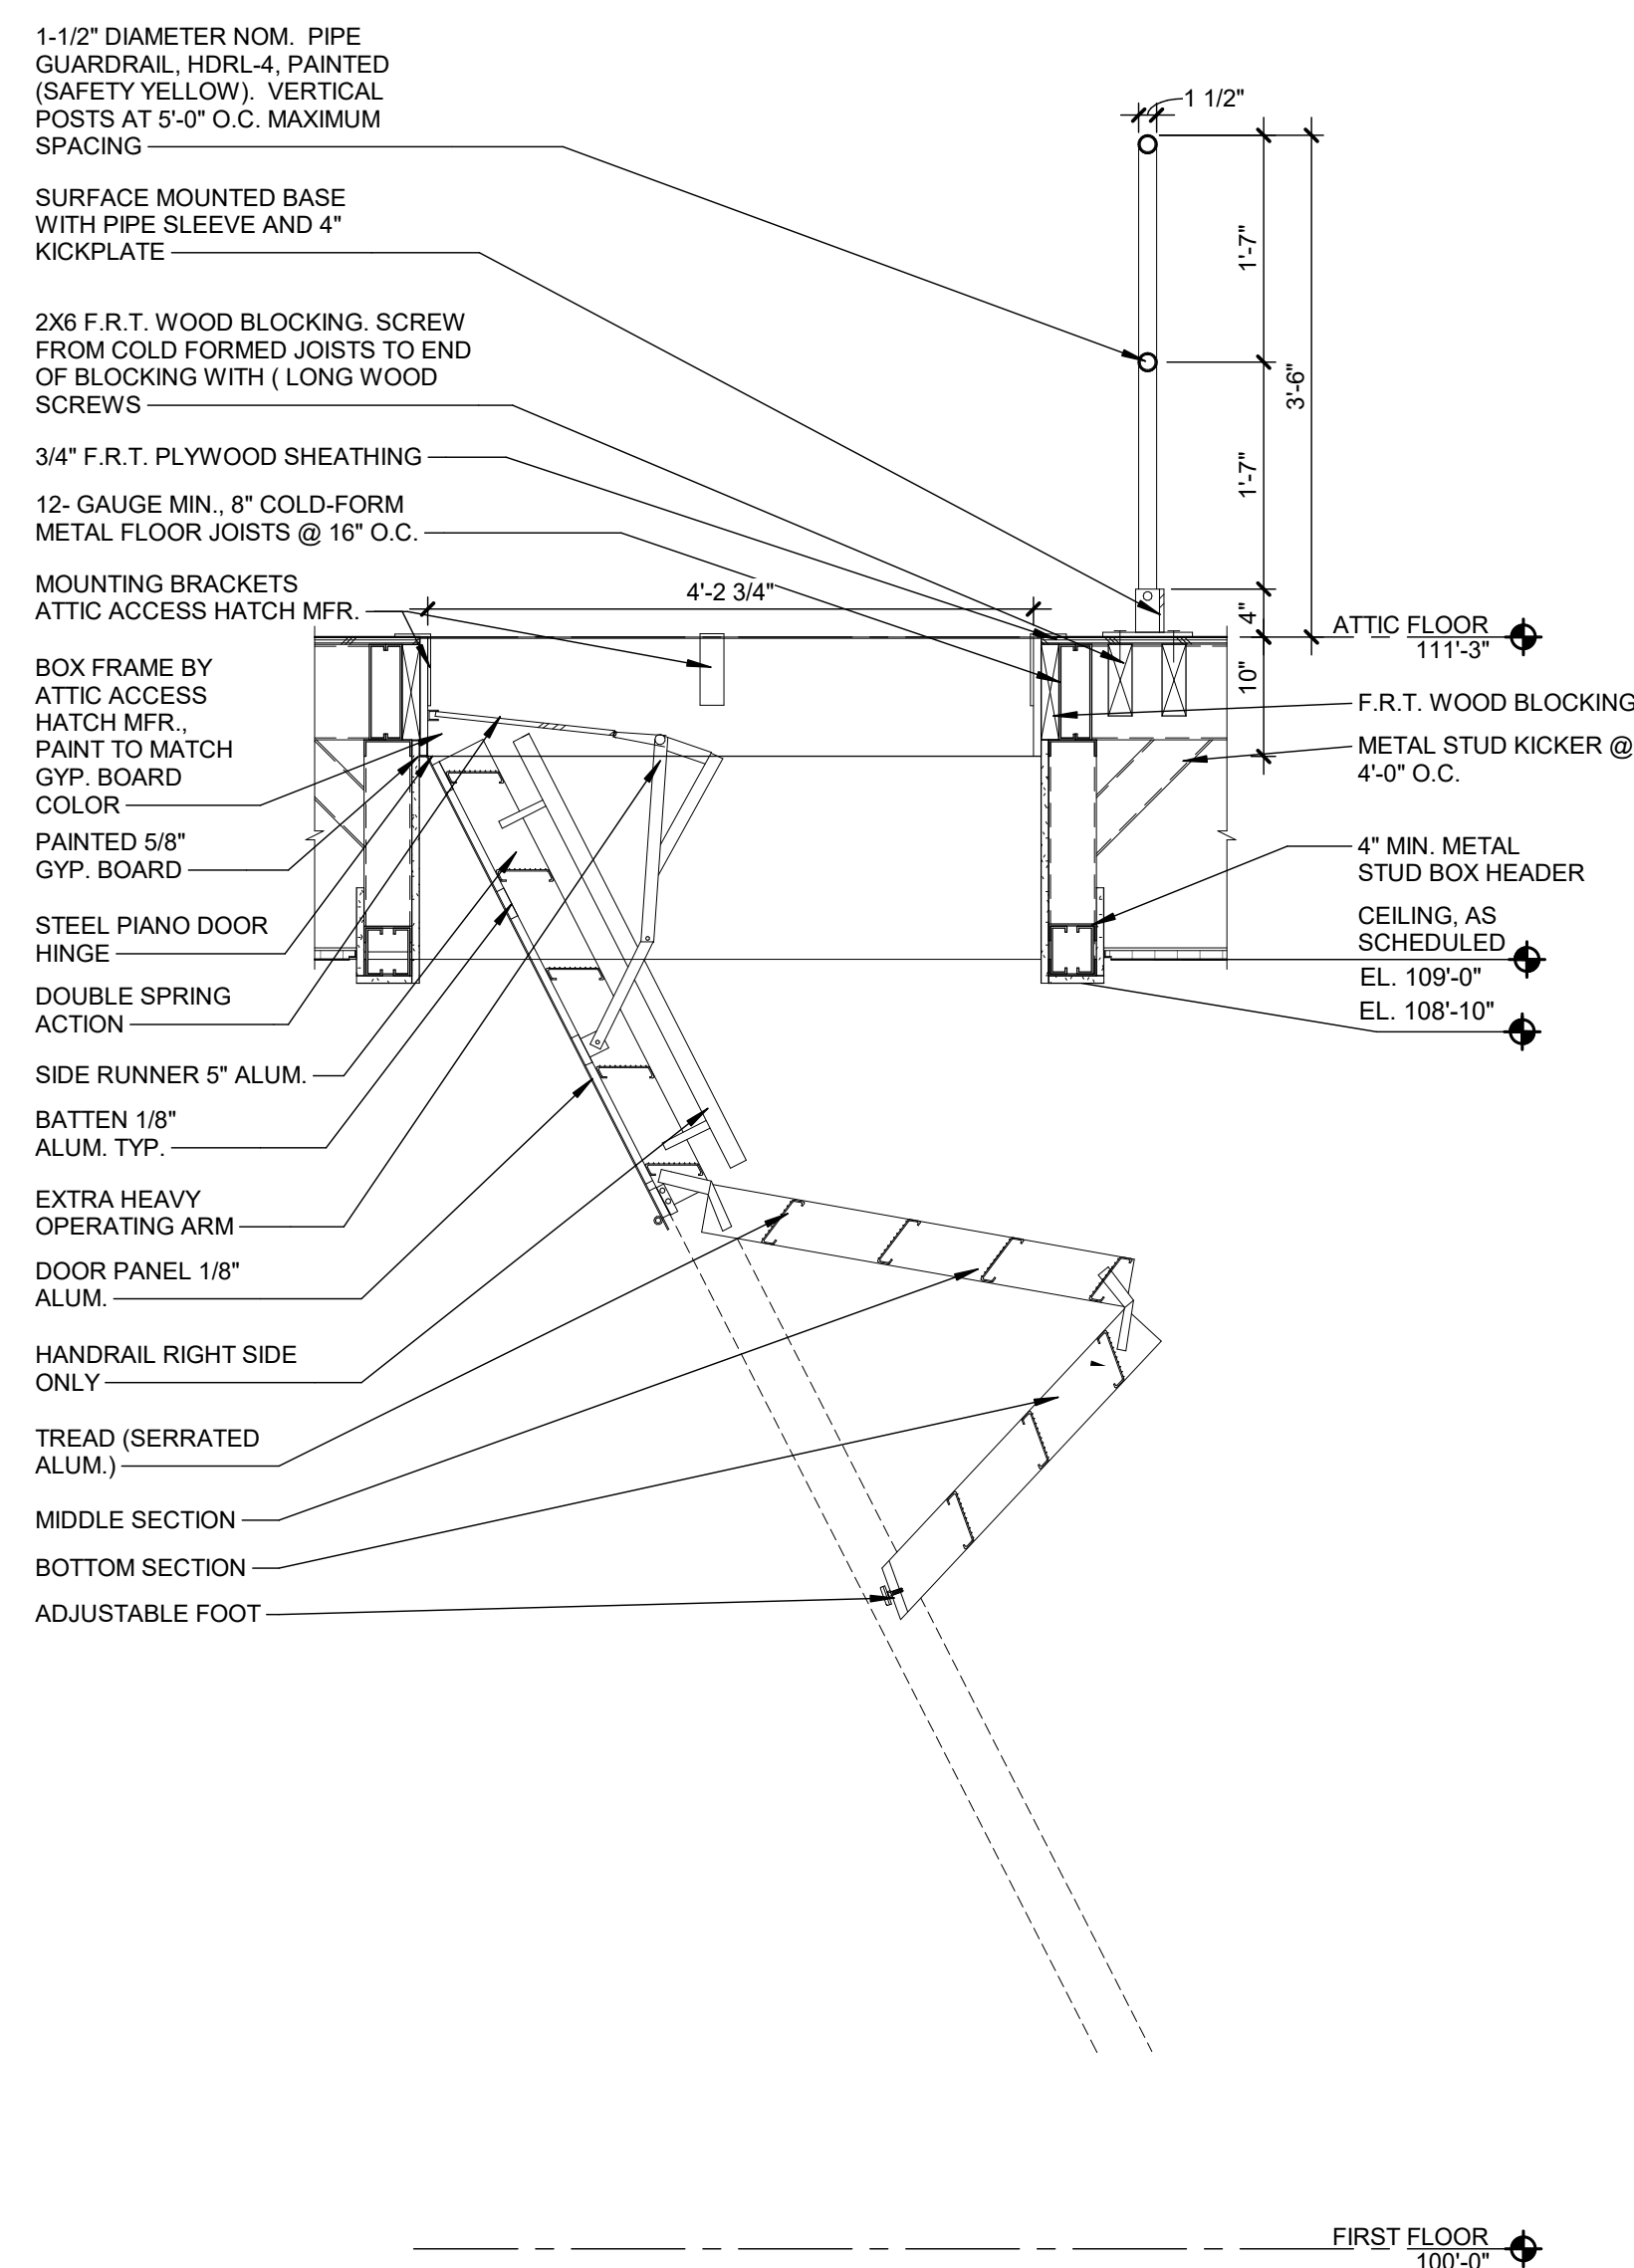


1 SECTION DETAIL
SCALE: 3/4" = 1'-0"

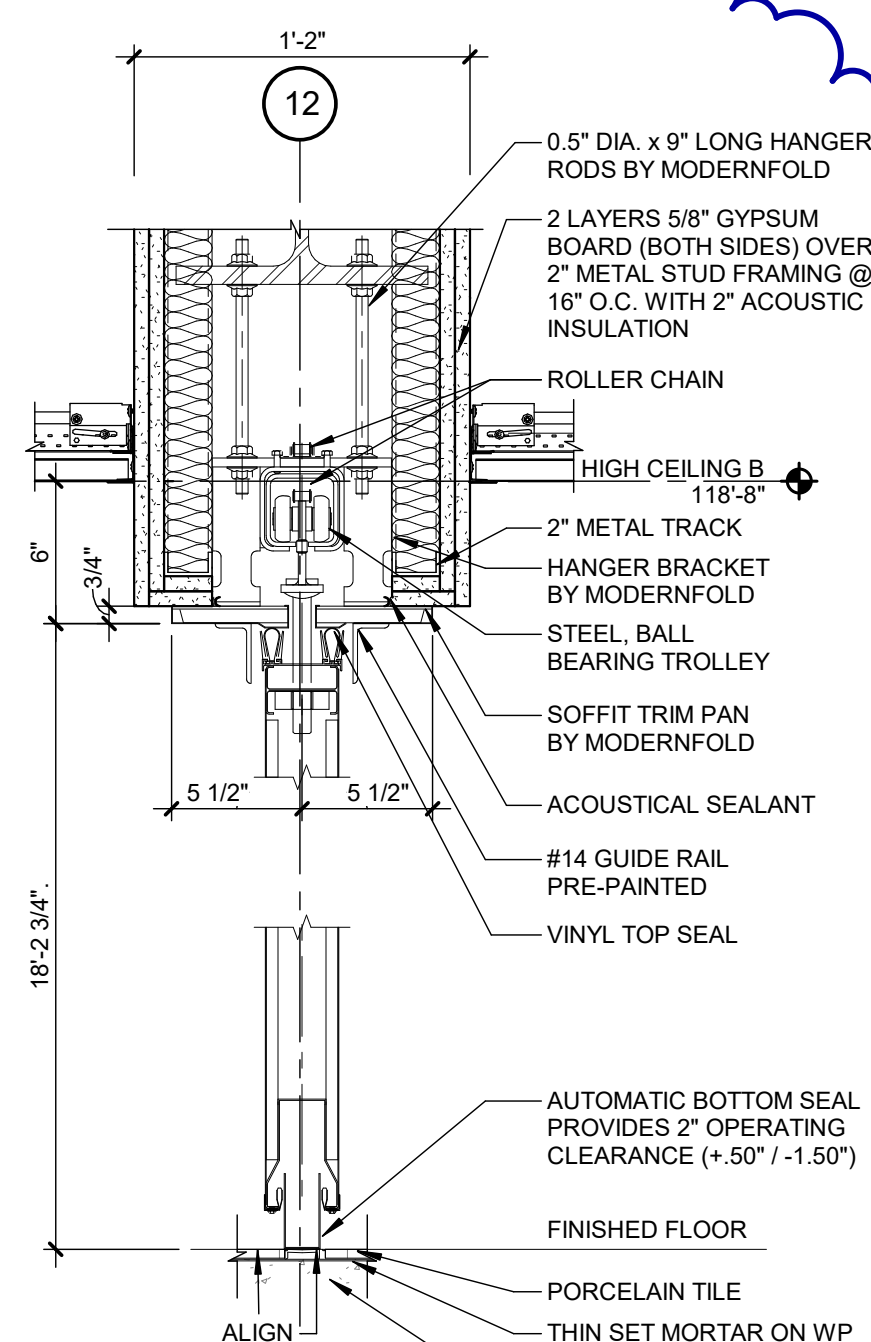


SECTION DETAIL

SCALE: 1 1/2" = 1'-0"

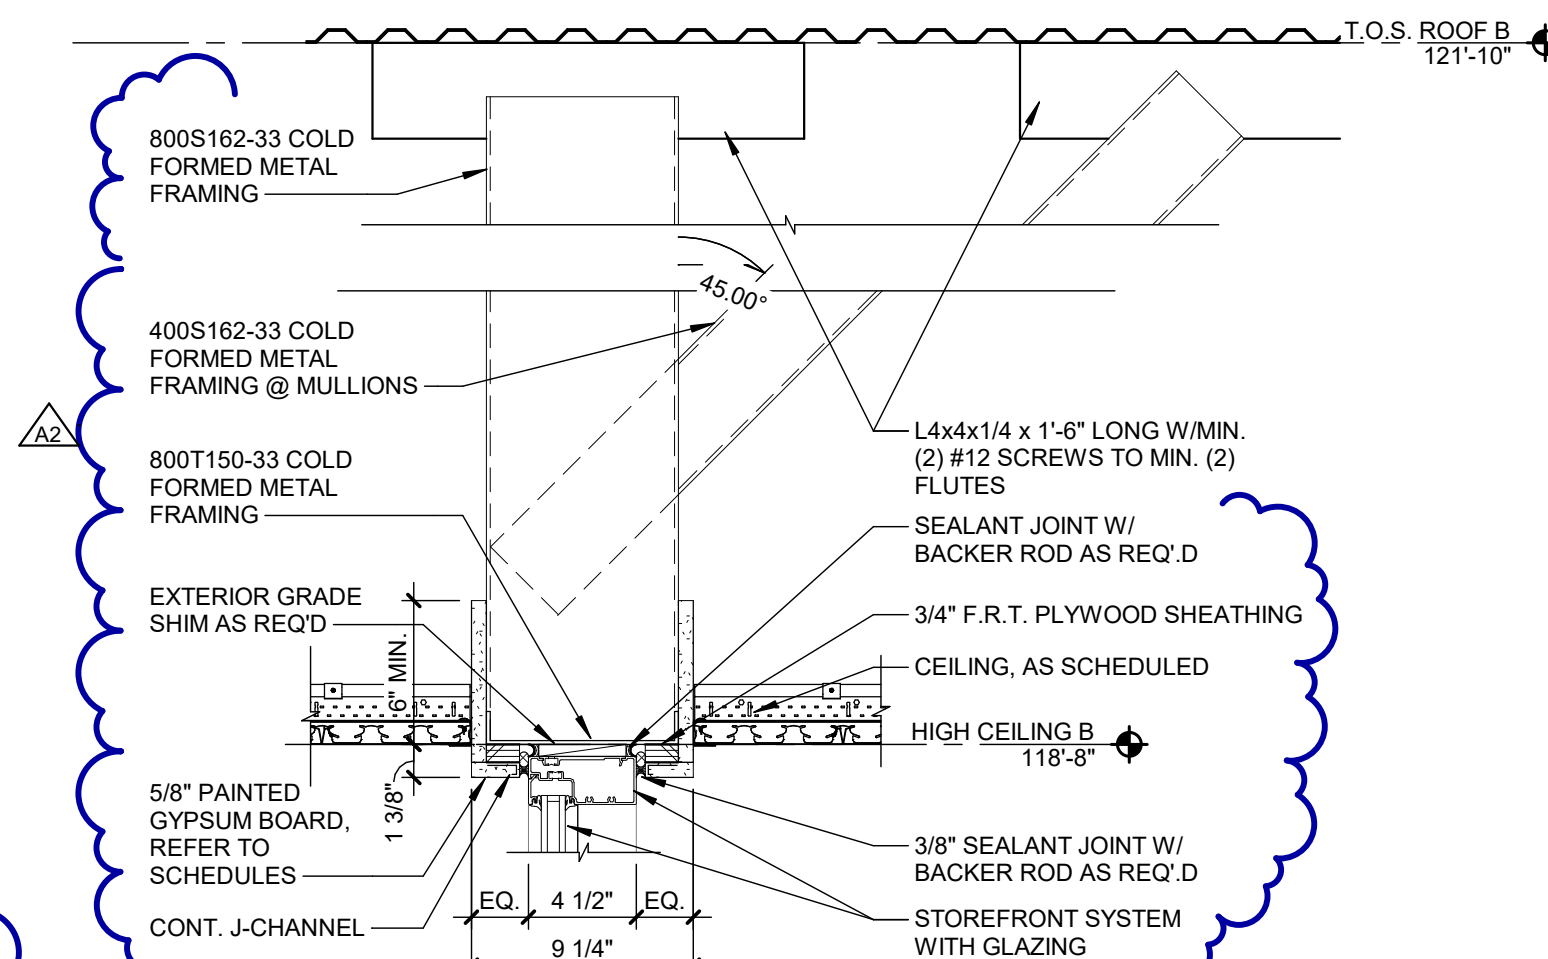

6 SECTION DETAIL
SCALE: 1 1/2" = 1'-0"

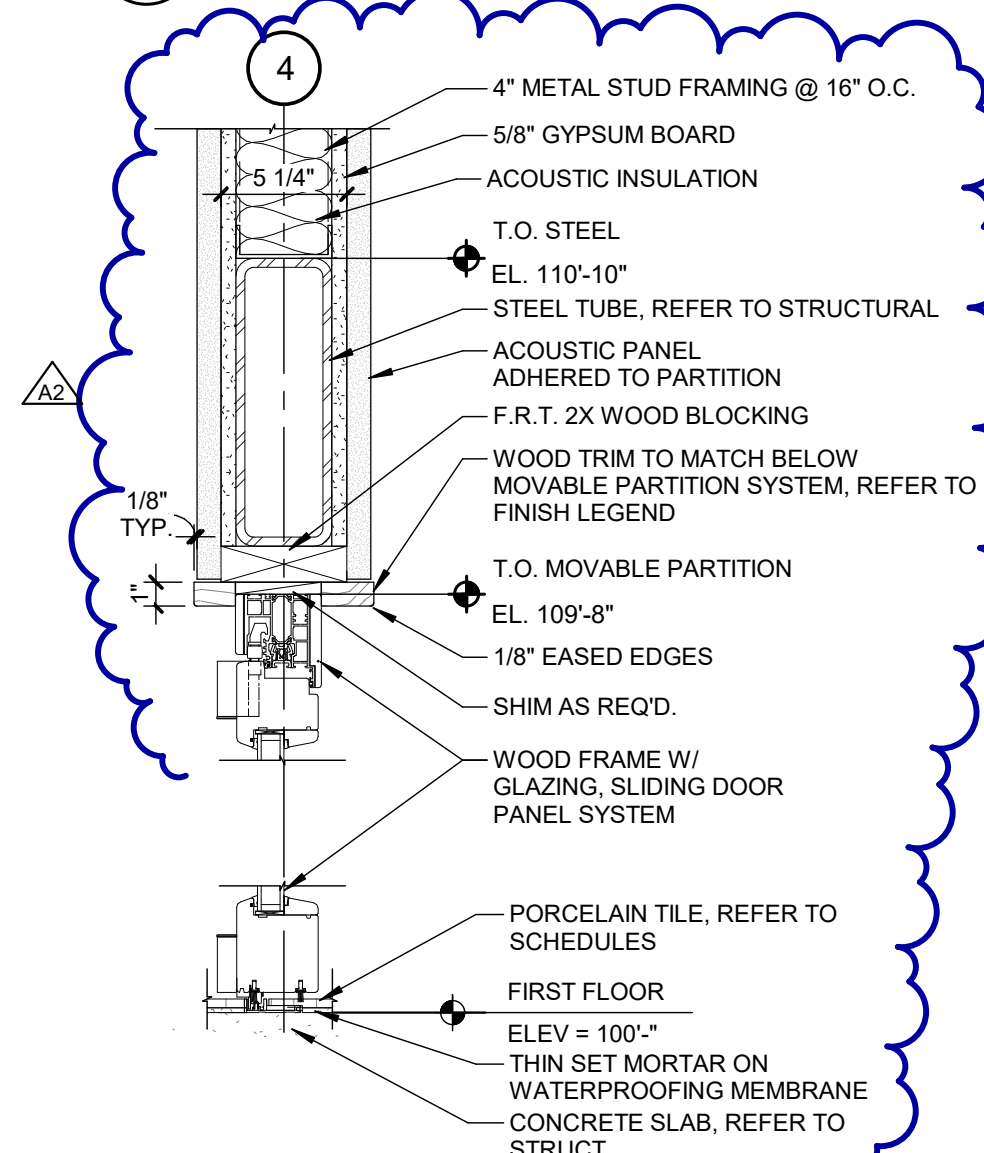


SECTION DETAIL


3

SCALE: 1 1/2" = 1'-0"


PLOT INFO: 10/27/2026 3:06:15 PM Autodesk Docs://2500281 - Van Buren Twp Lake House/2026_A_2500281.rvt

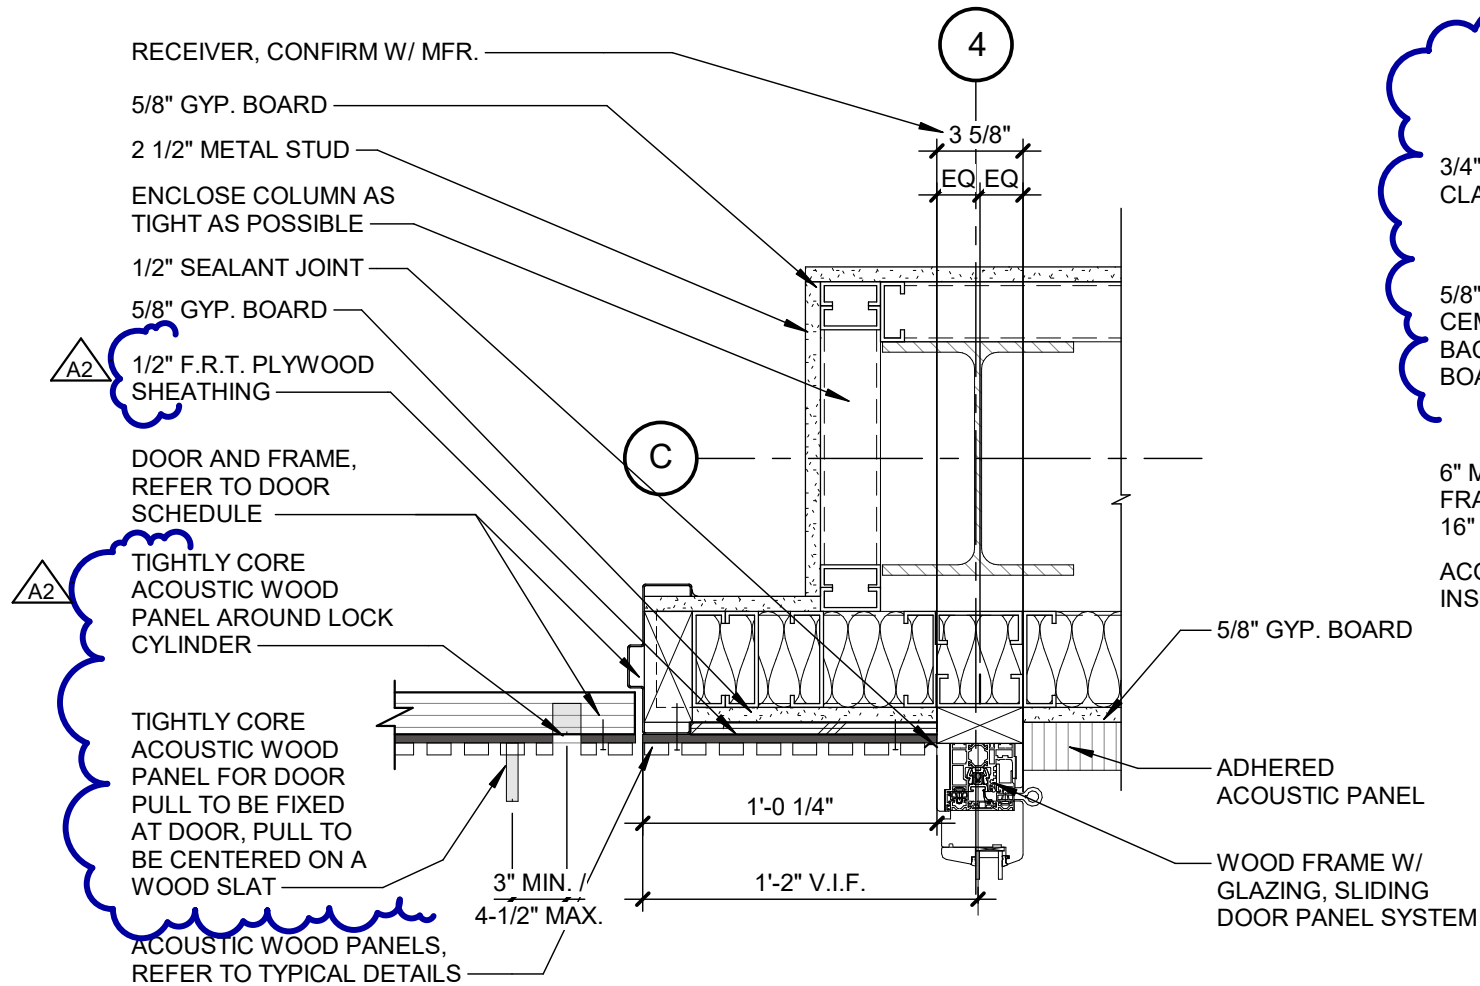


5 PLAN DETAIL
SCALE: 1 1/2" = 1'-0"

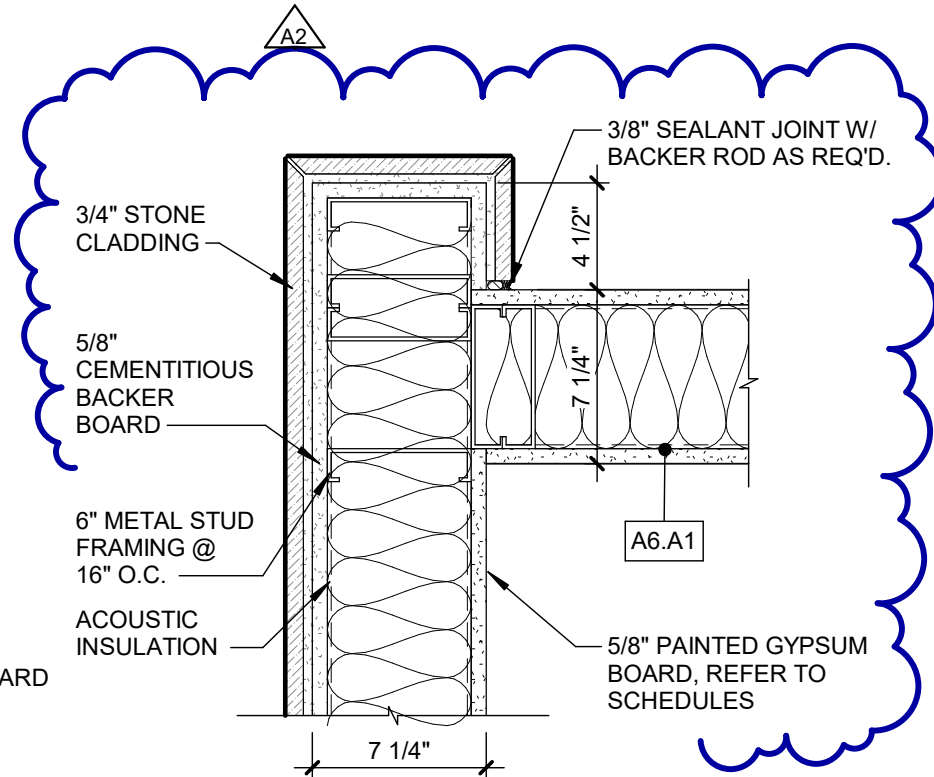


4 PLAN DETAIL
SCALE: 1 1/2" = 1'-0"

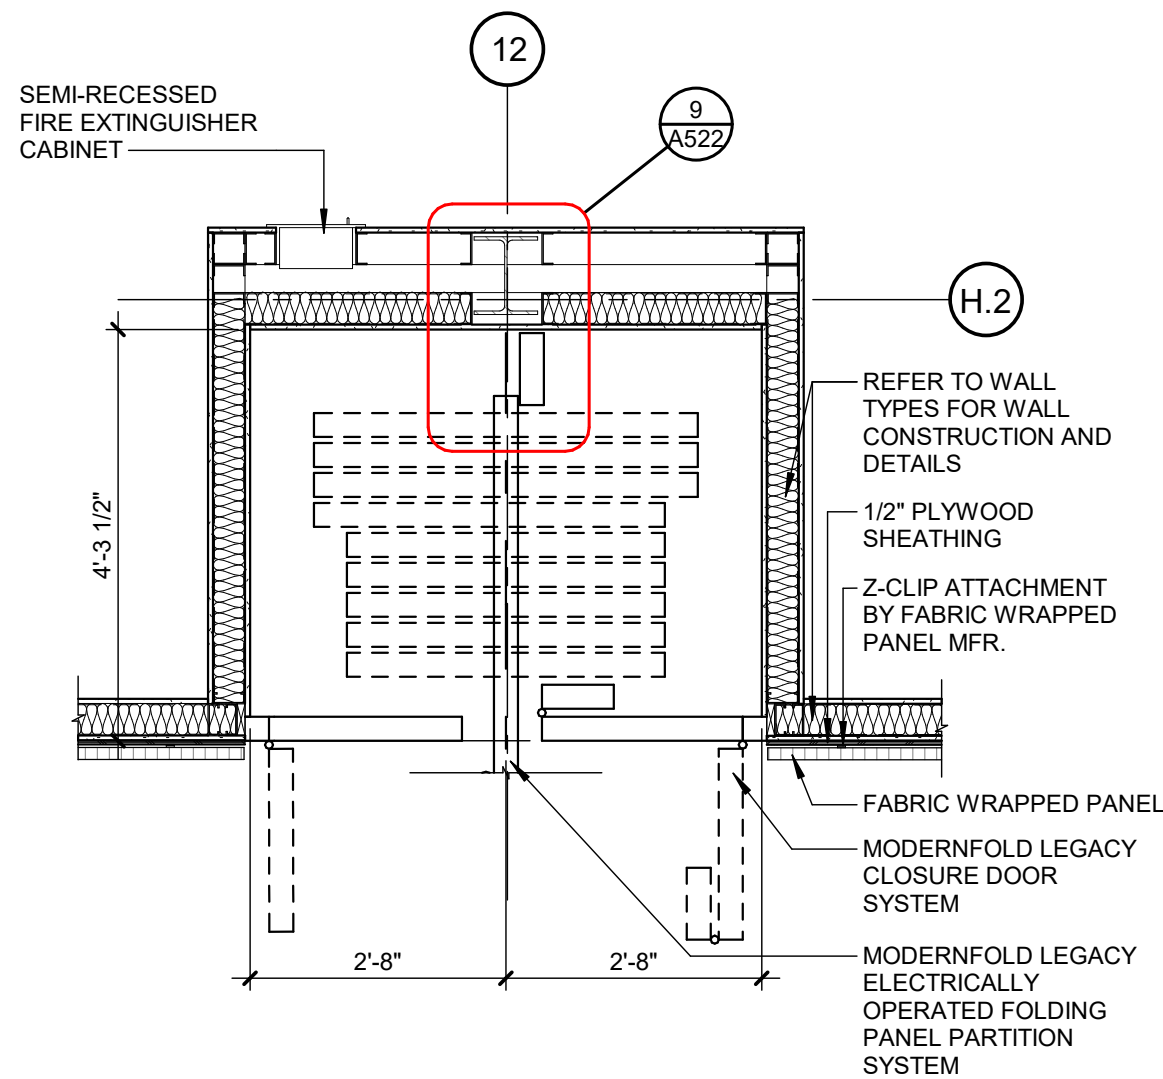


3 PLAN DETAIL
SCALE: 1/2" = 1'-0"

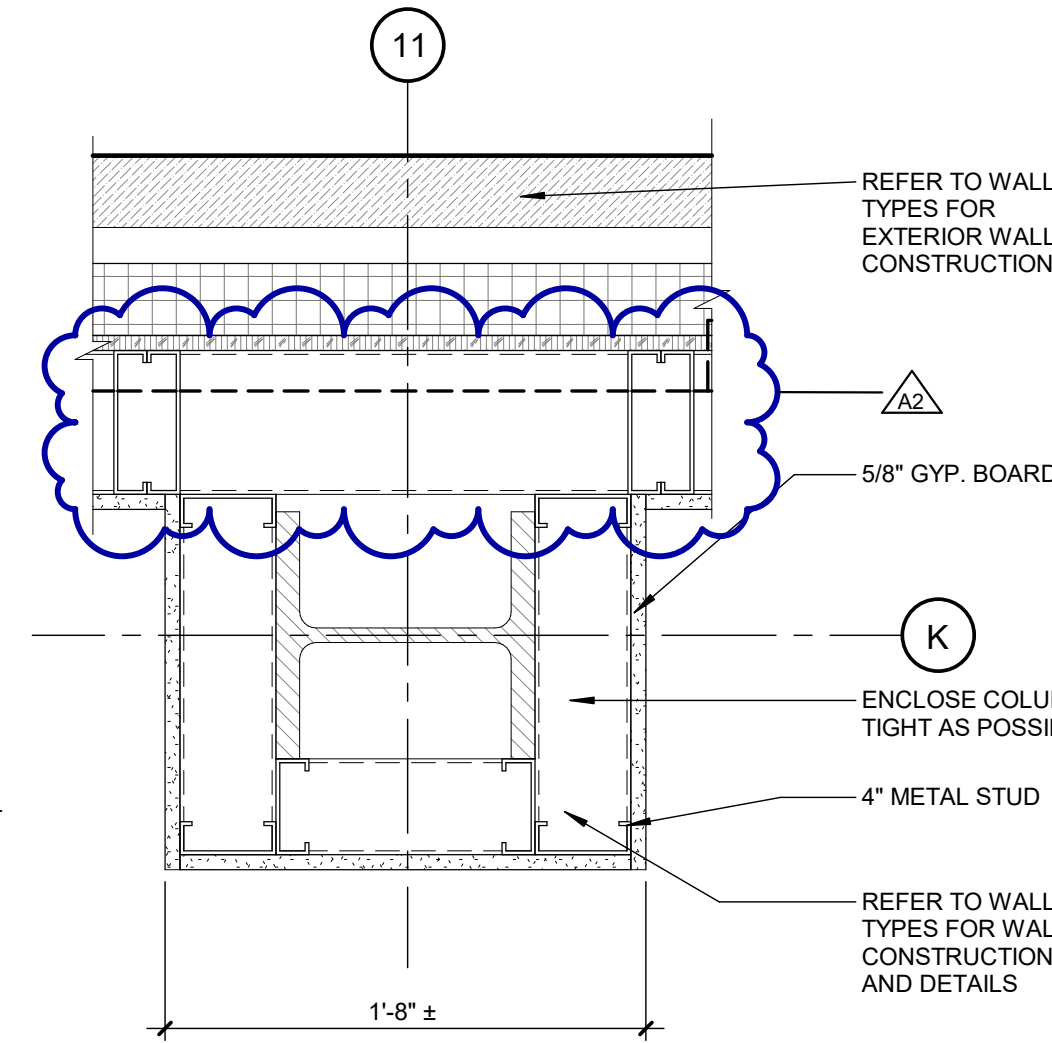


2 PLAN DETAIL
SCALE: 1 1/2" = 1'-0"

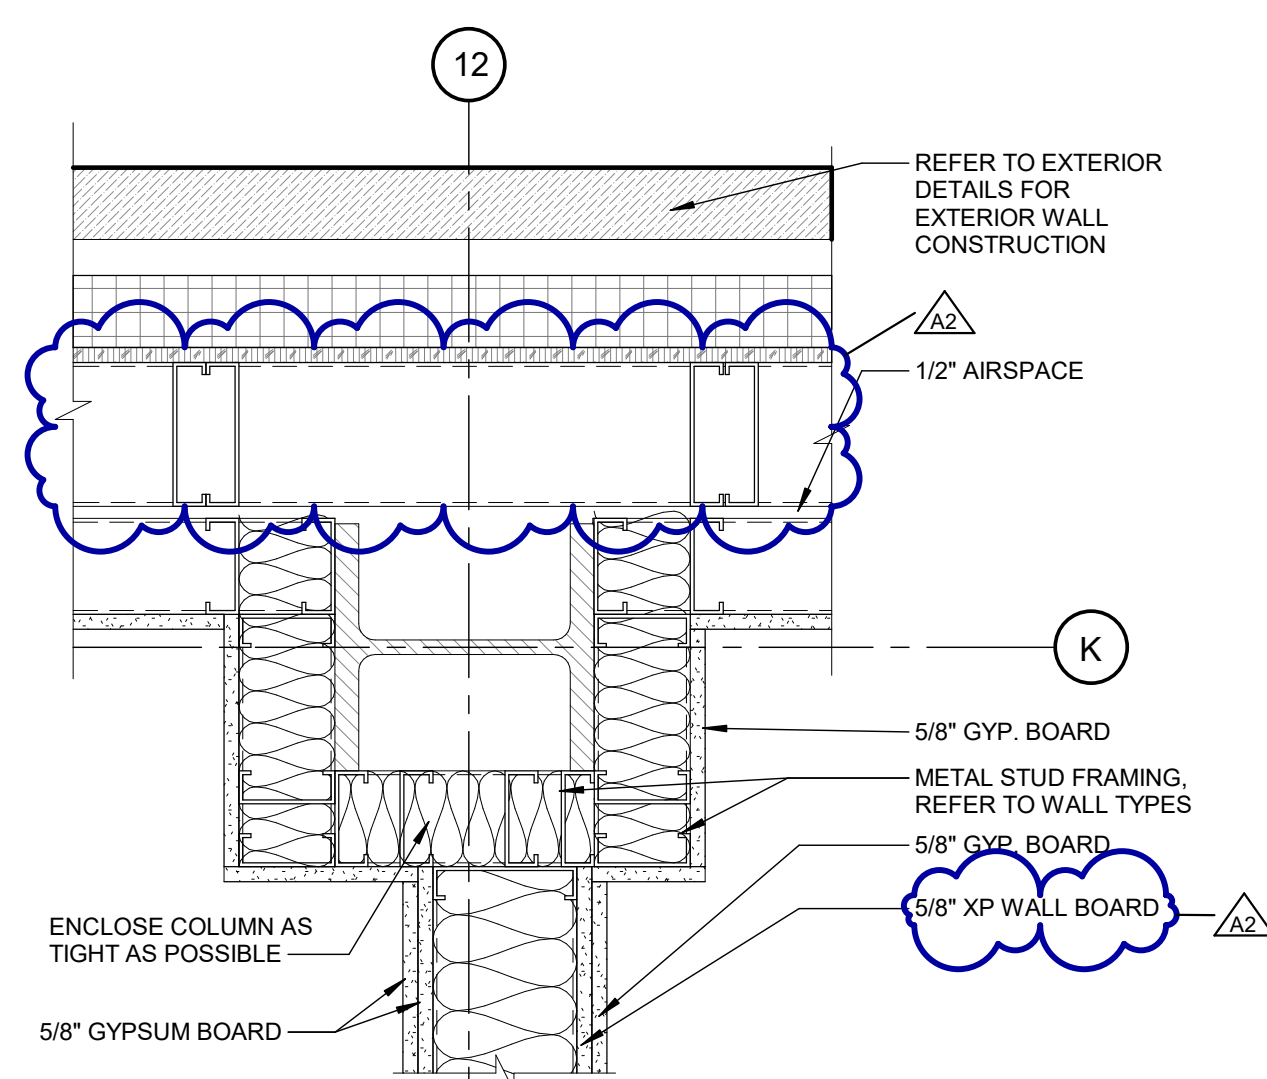


1 PLAN DETAIL
SCALE: 1 1/2" = 1'-0"

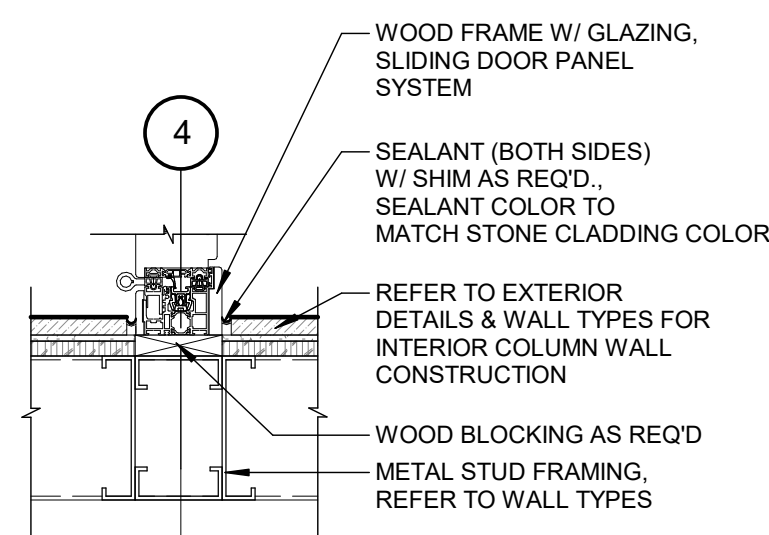


11 PLAN DETAIL
SCALE: 1 1/2" = 1'-0"

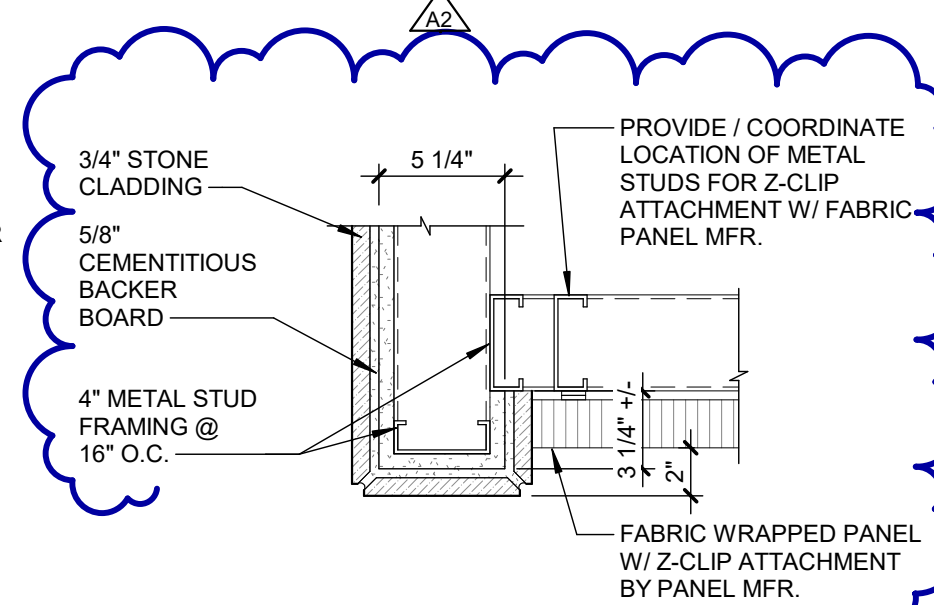


10 PLAN DETAIL
SCALE: 1 1/2" = 1'-0"

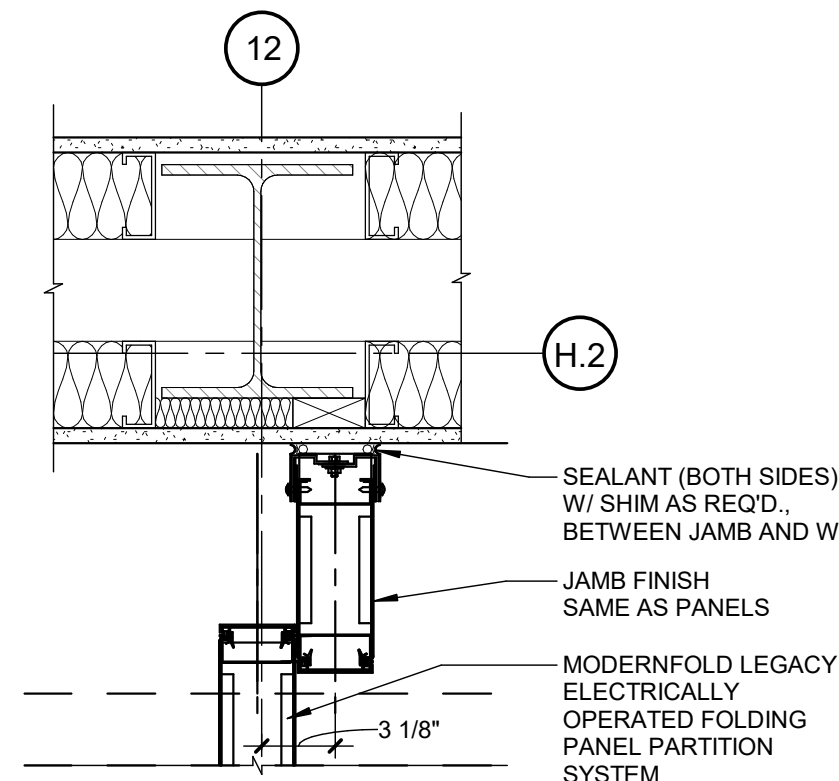


9 PLAN DETAIL
SCALE: 1 1/2" = 1'-0"

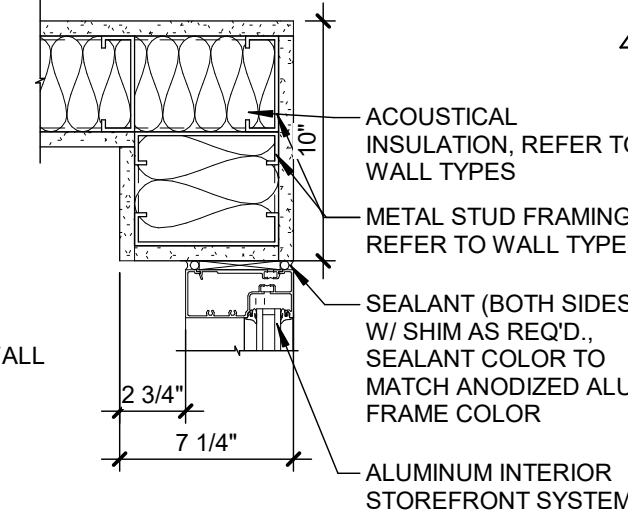


8 PLAN DETAIL
SCALE: 1 1/2" = 1'-0"

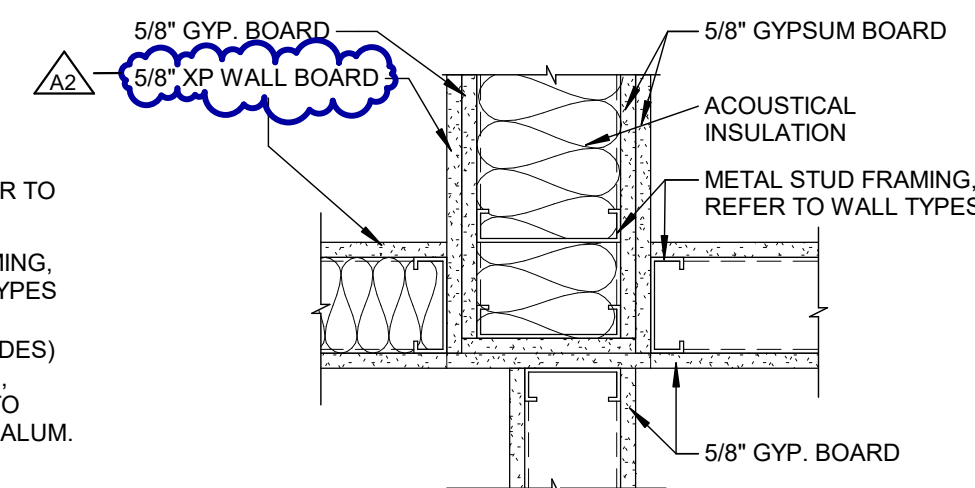


7 PLAN DETAIL
SCALE: 1 1/2" = 1'-0"

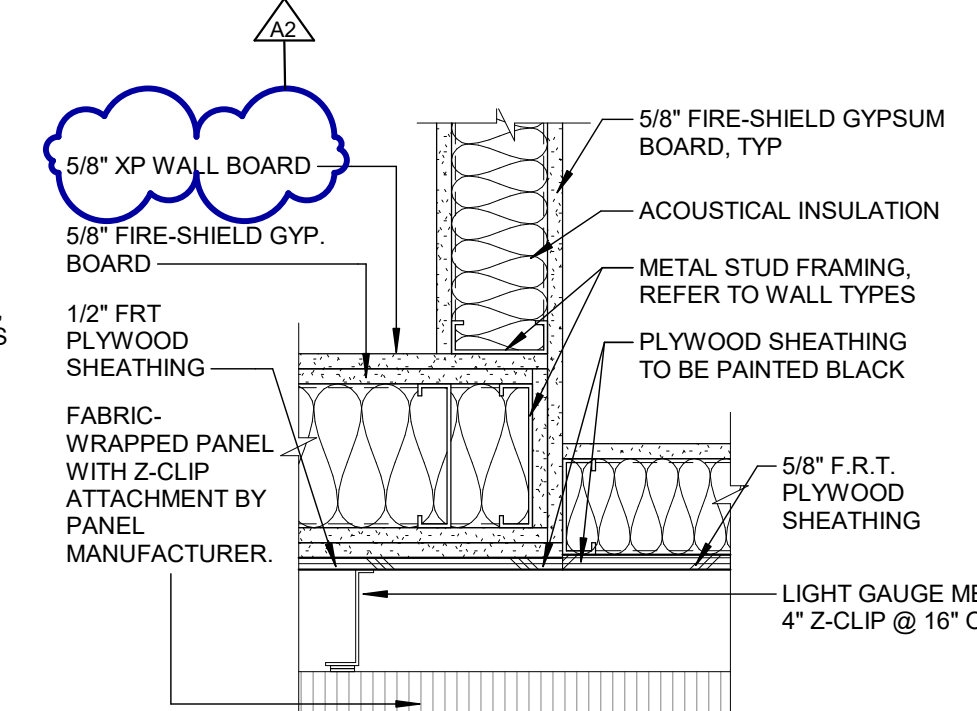


6 PLAN DETAIL
SCALE: 1 1/2" = 1'-0"

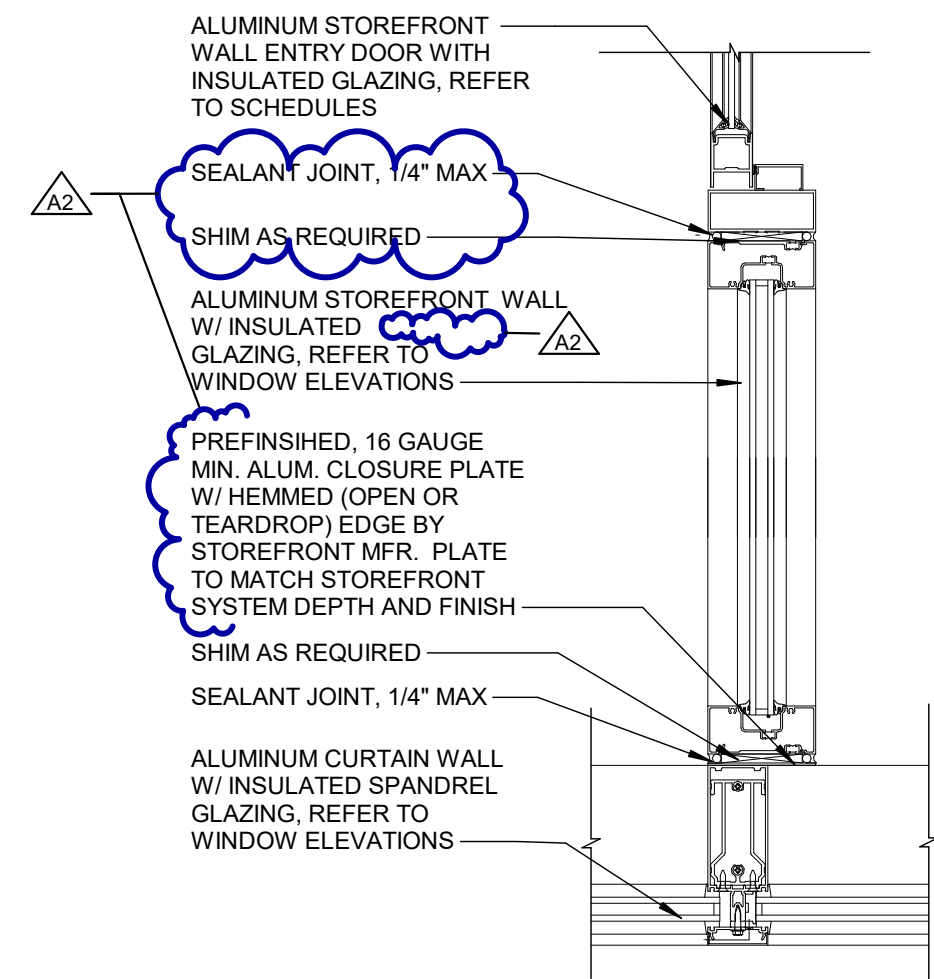


16 PLAN DETAIL
SCALE: 1 1/2" = 1'-0"

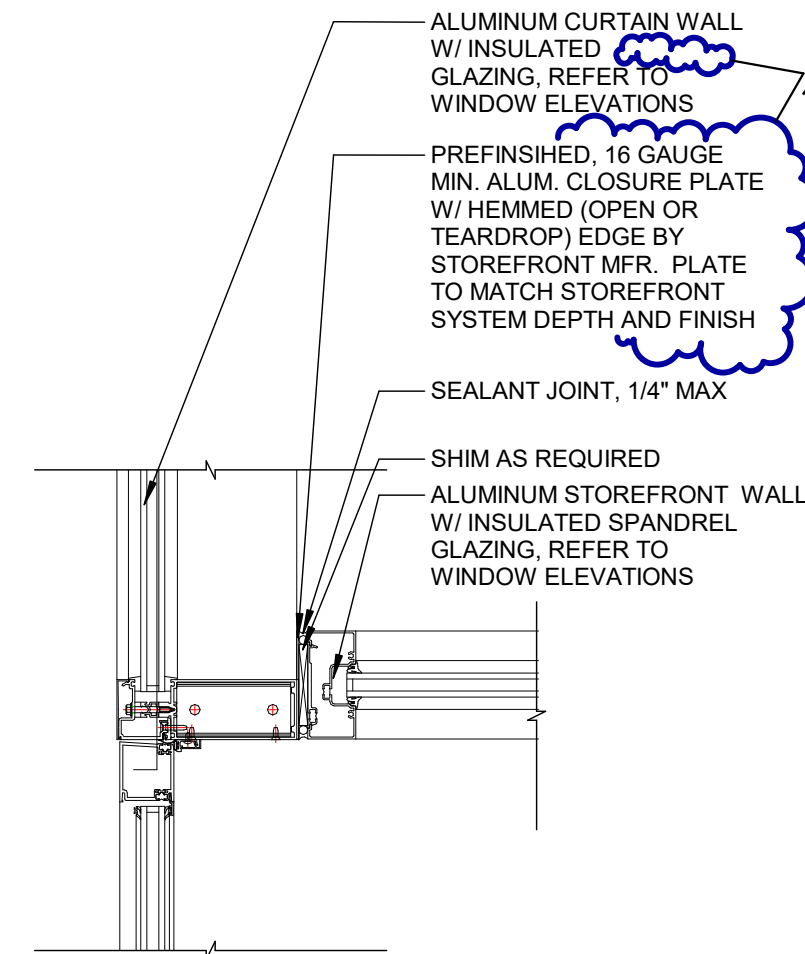



15 PLAN DETAIL
SCALE: 1 1/2" = 1'-0"

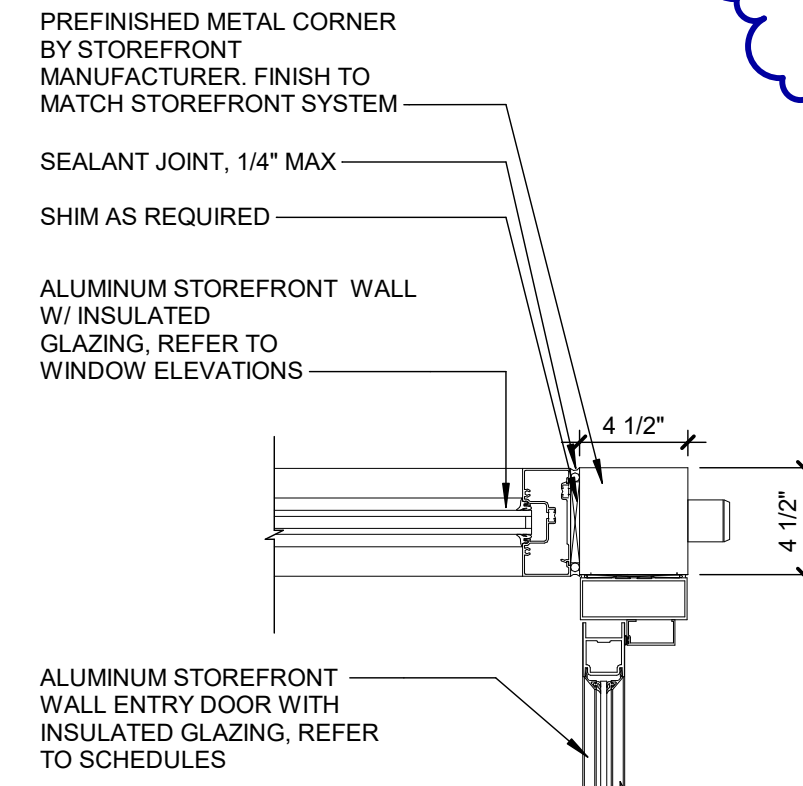

14 PLAN DETAIL
SCALE: 1 1/2" = 1'-0"

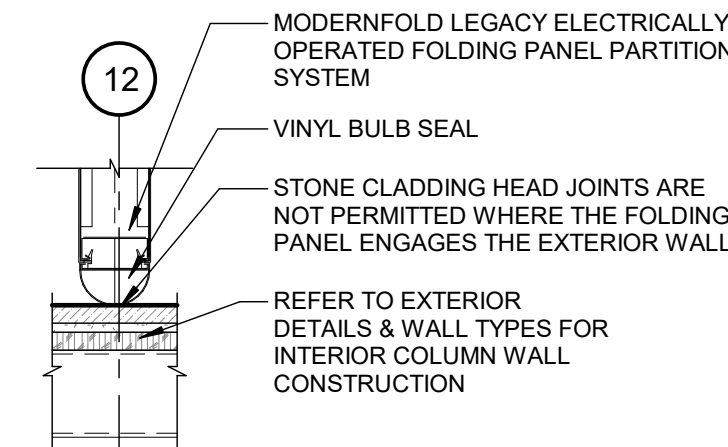

13 PLAN DETAIL
SCALE: 1 1/2" = 1'-0"

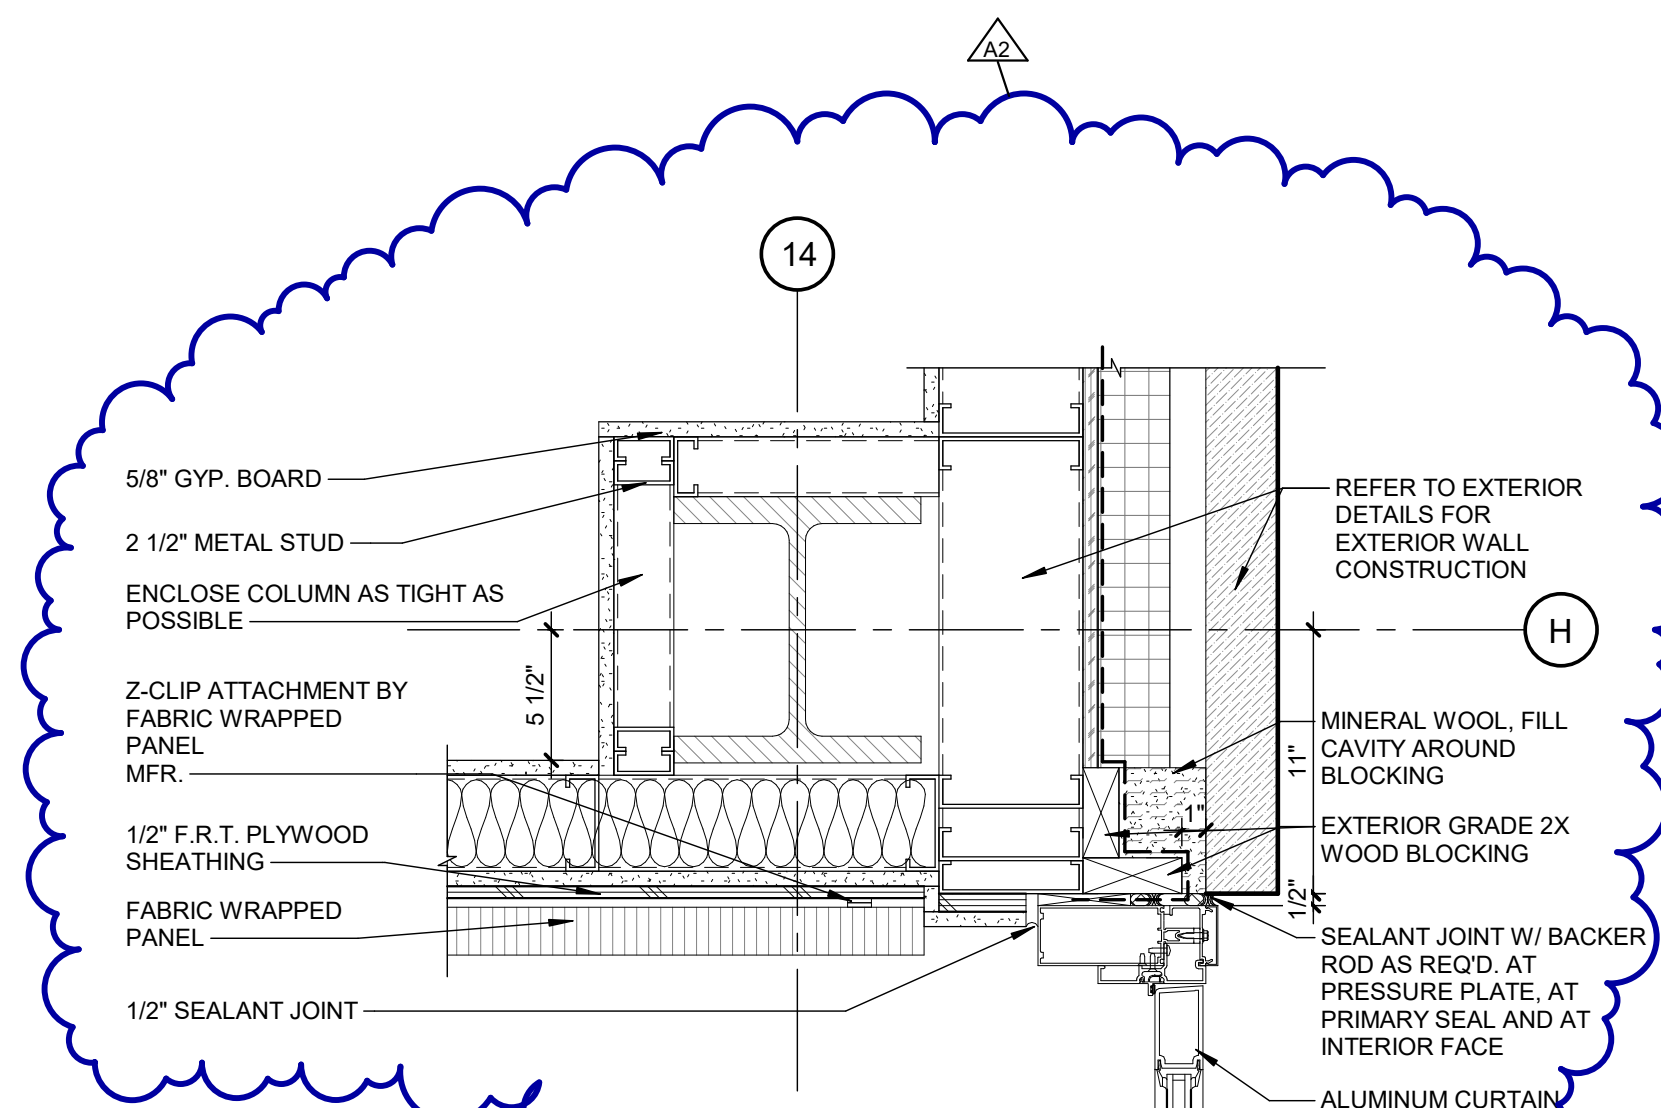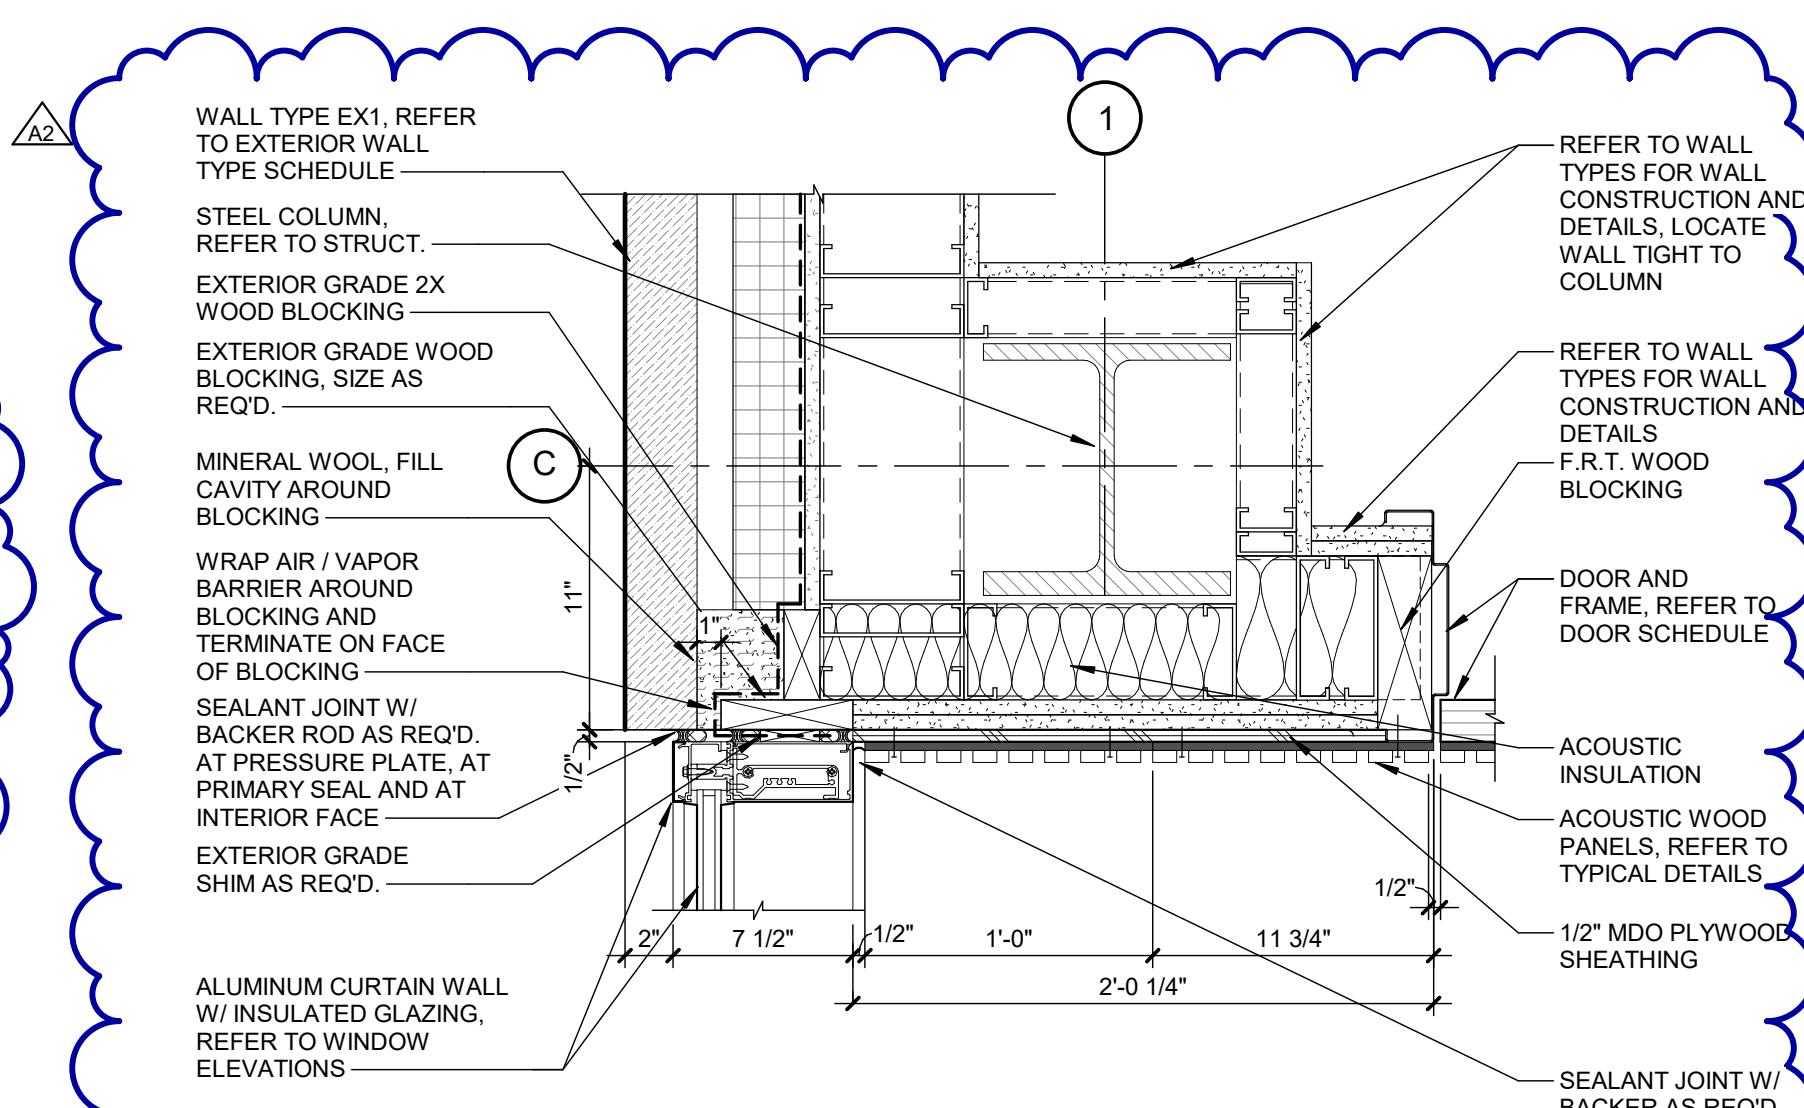

Van Buren Charter Township

Van Buren Township, MI

The Lakeside Park



REVISIONS		
10/27/2026	A2	ADDENDUM NO. 2

10/12/2026	BIDS & PERMIT
09/21/2026	CD PEER REVIEW
08/09/2026	CD TEAM REVIEW
08/10/2026	CD 50% PROGRESS
08/22/2026	DD OWNER REVIEW
06/15/2026	DD PEER REVIEW
06/08/2026	DD 90 % PROGRESS
05/18/2026	DD 50 % PROGRESS
02/23/2026	SD OWNER REVIEW
02/13/2026	SD PEER REVIEW
02/09/2026	SD PROGRESS REVIEW











Drawn By IOLKHOVESKA
Designer LFINNEY
Reviewer WLAPSON
Manager CKRETOVIC

Hard copy is intended to be 24"x36" when plotted. Scale(s) indicated and graphic quality may not be accurate for any other size.

PROJECT NO.
2500281
SHEET NO.

A522

©Copyright 2026
All Rights Reserved

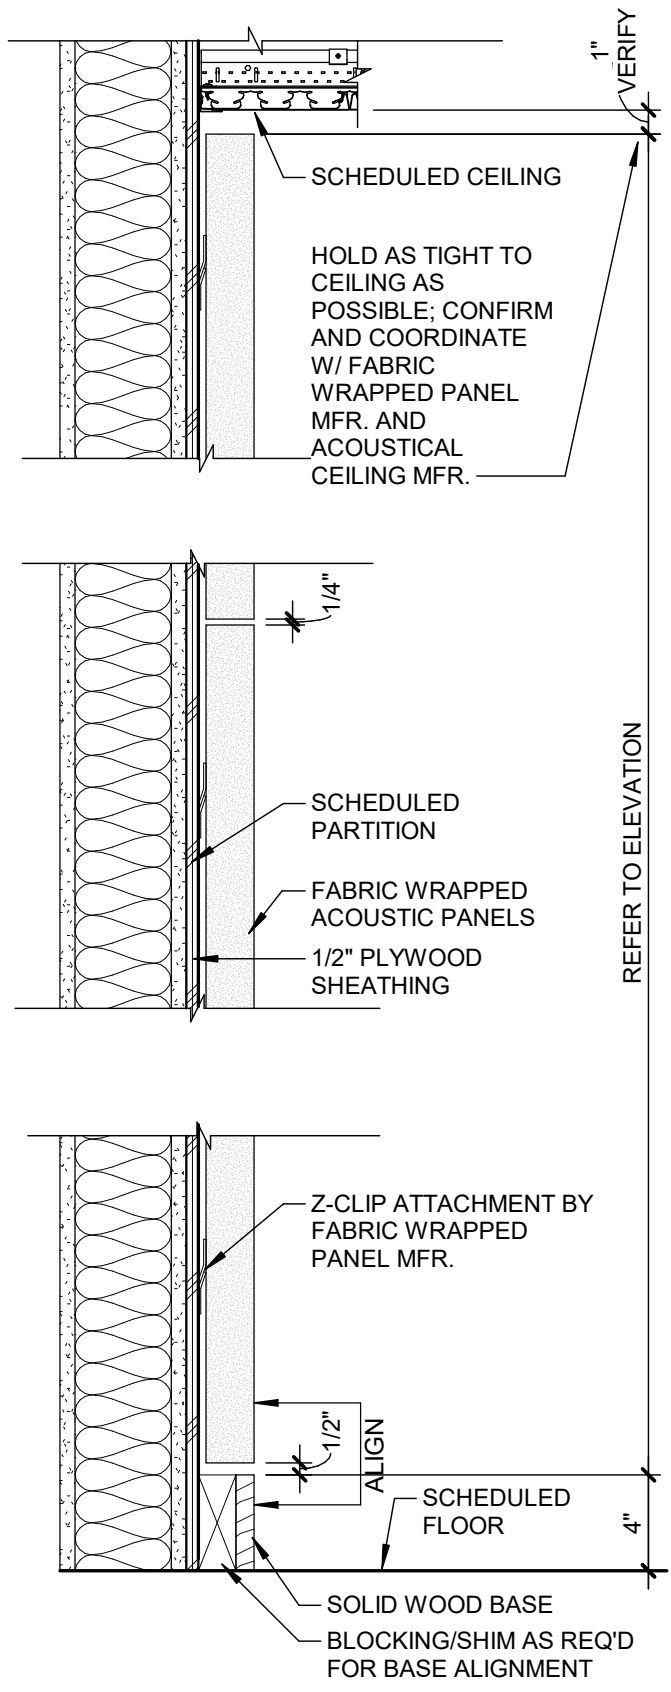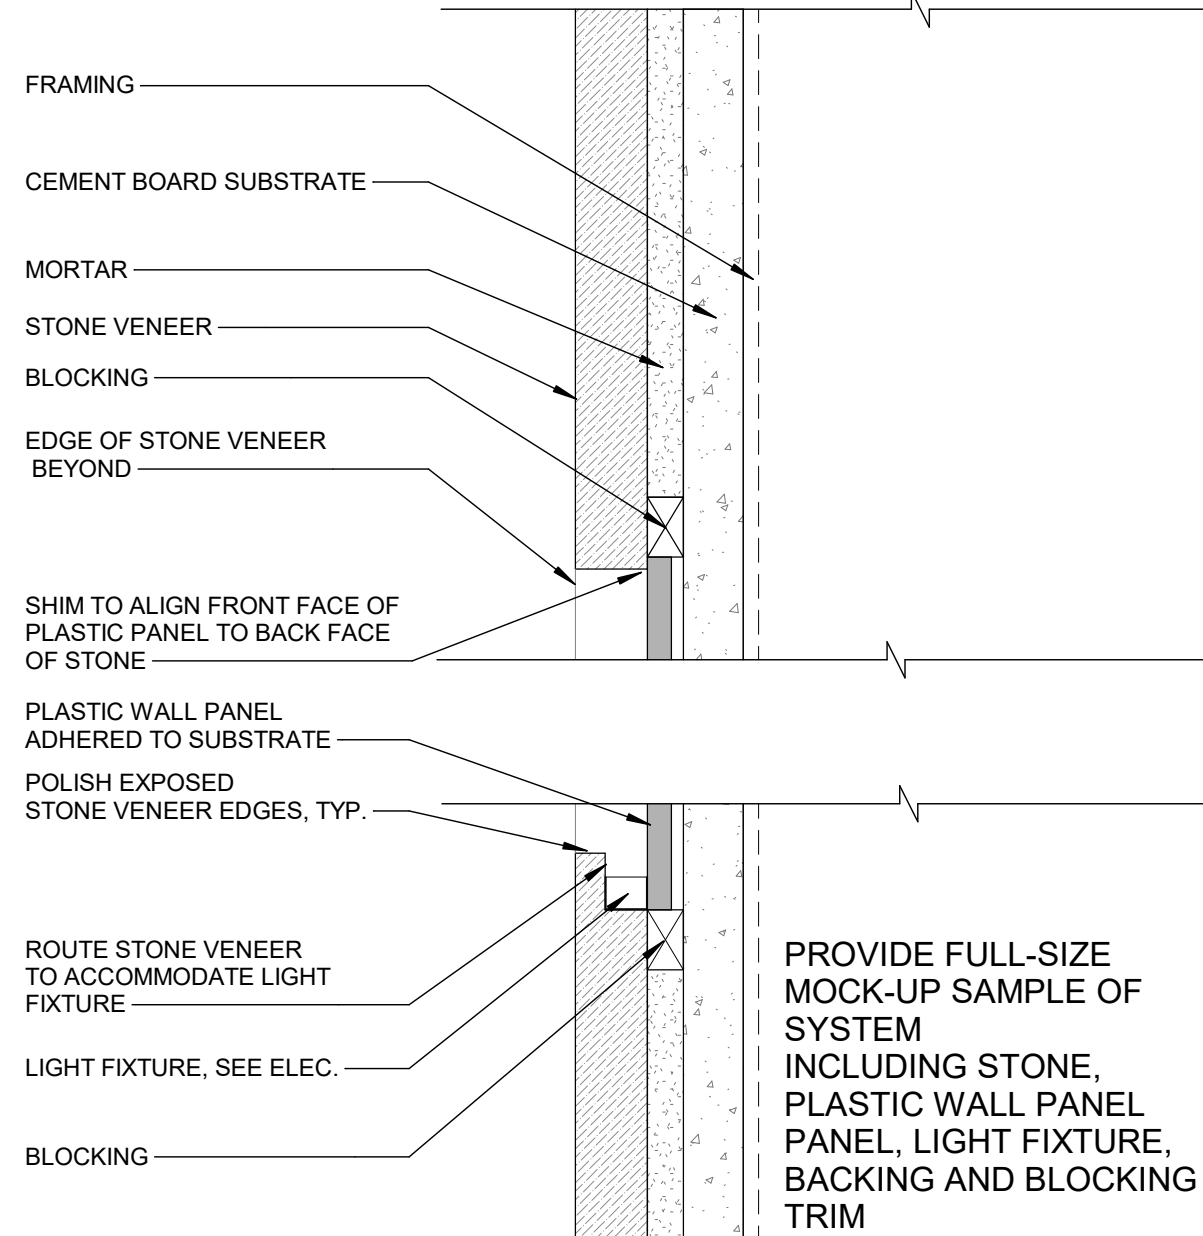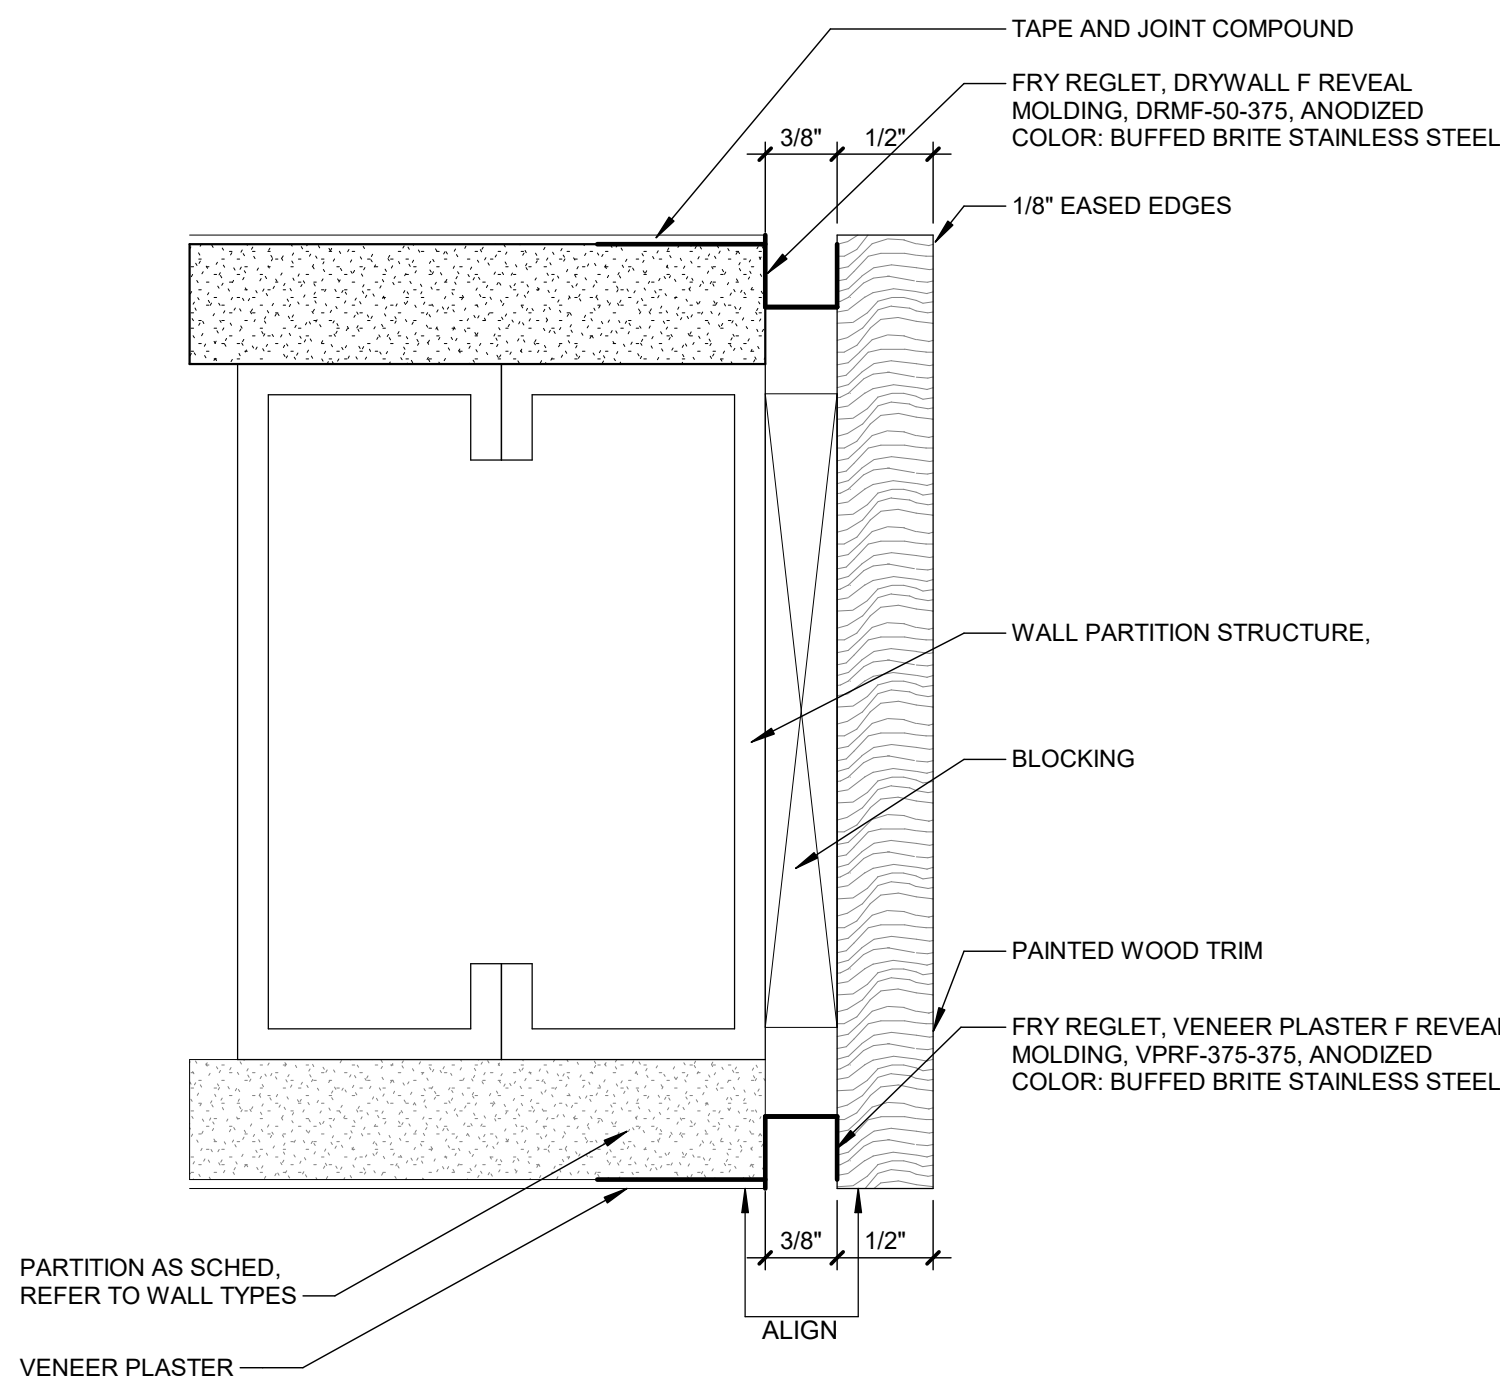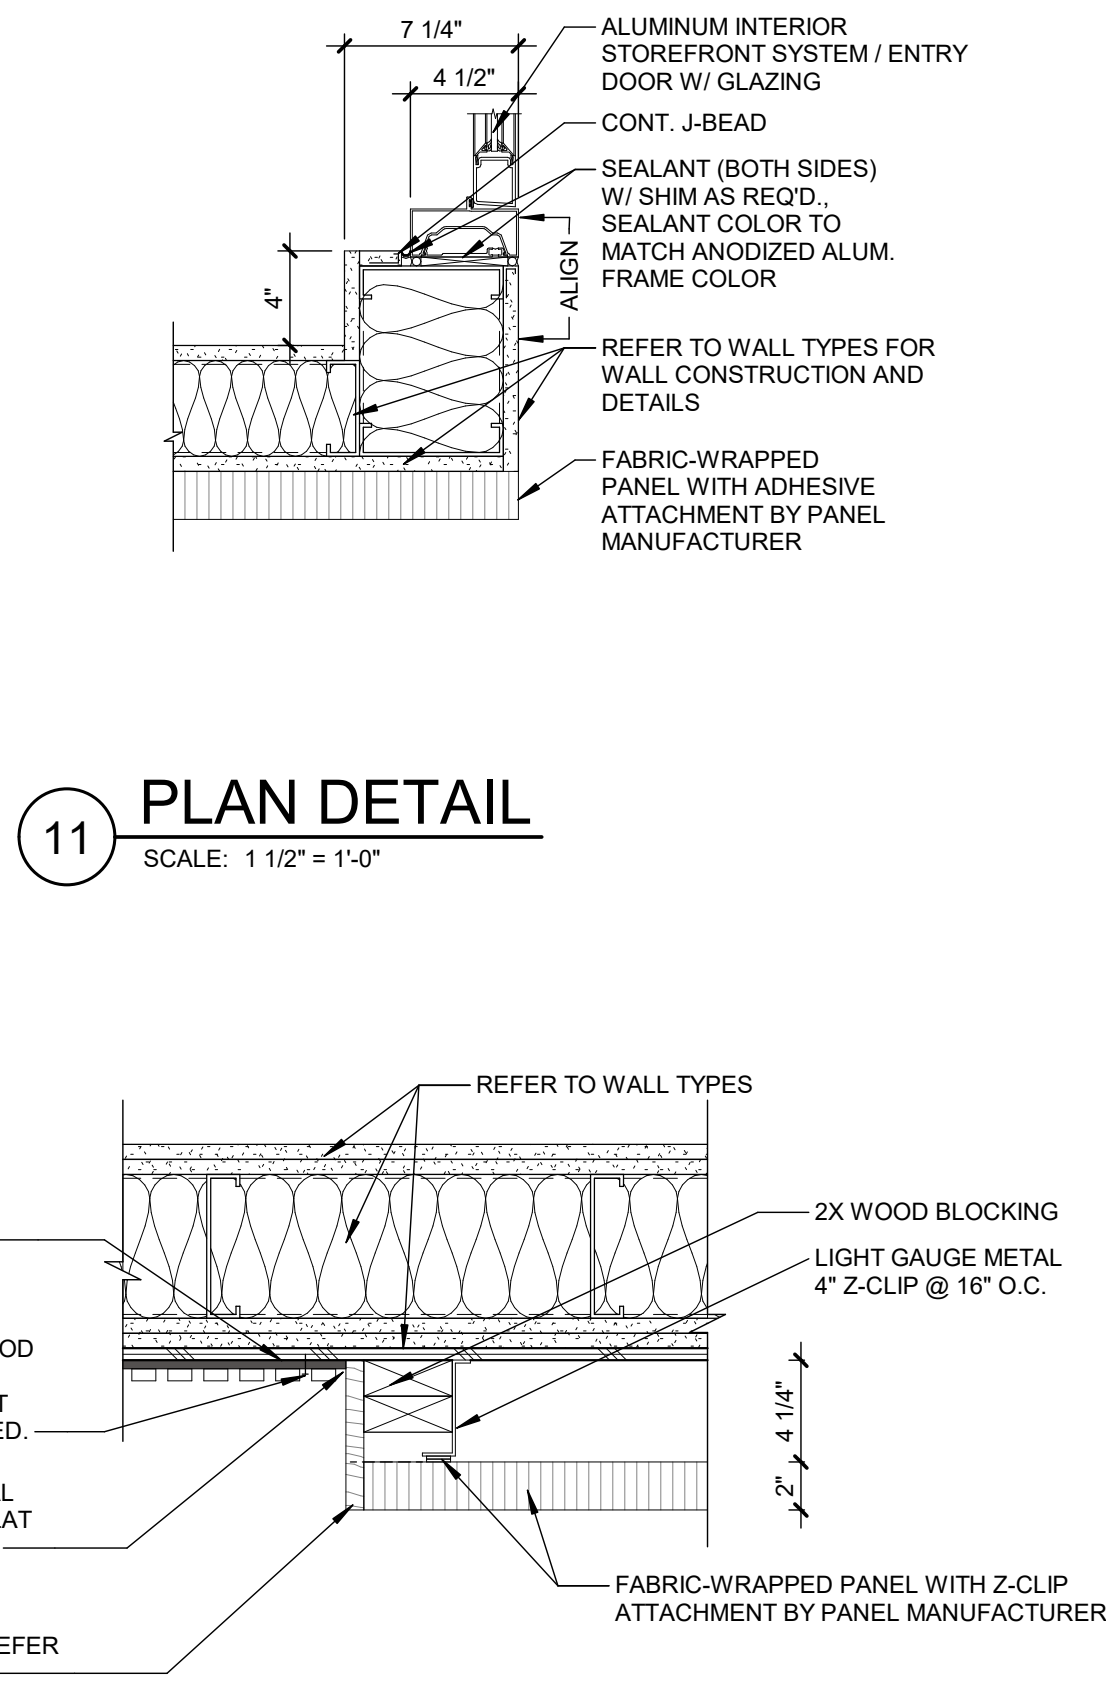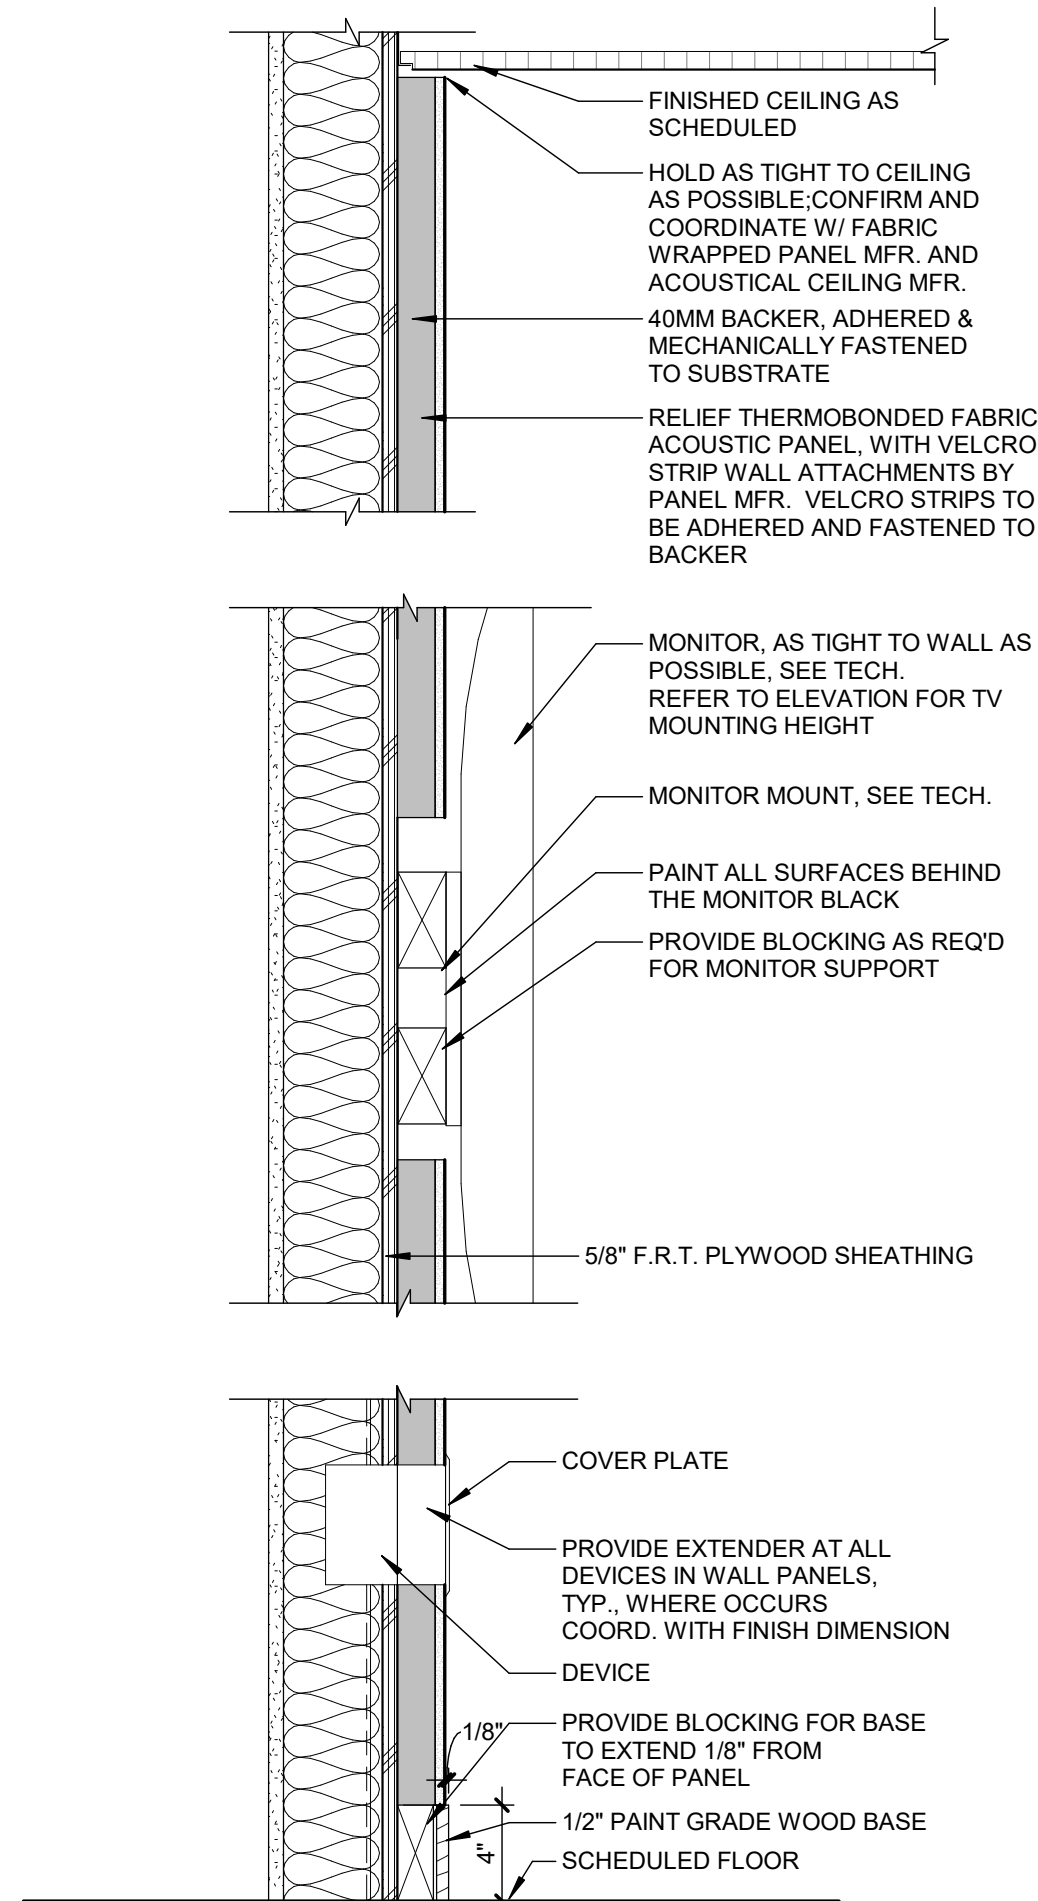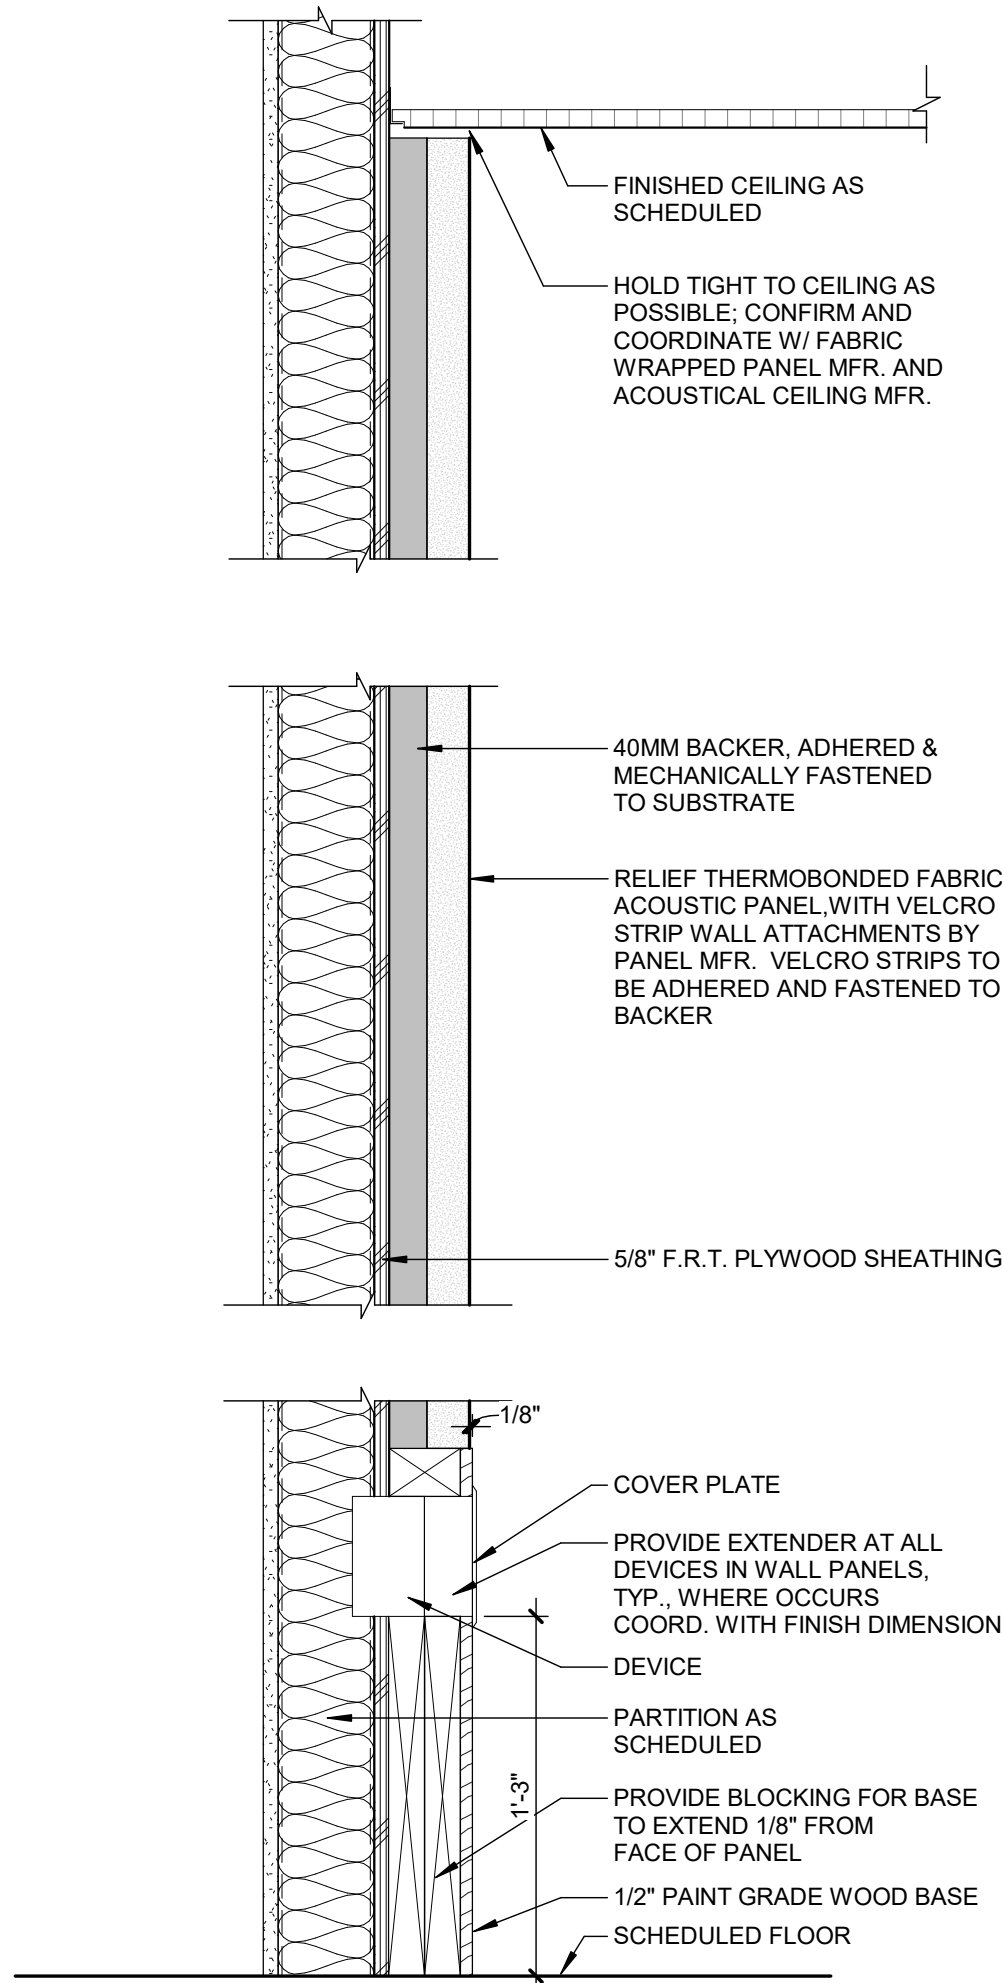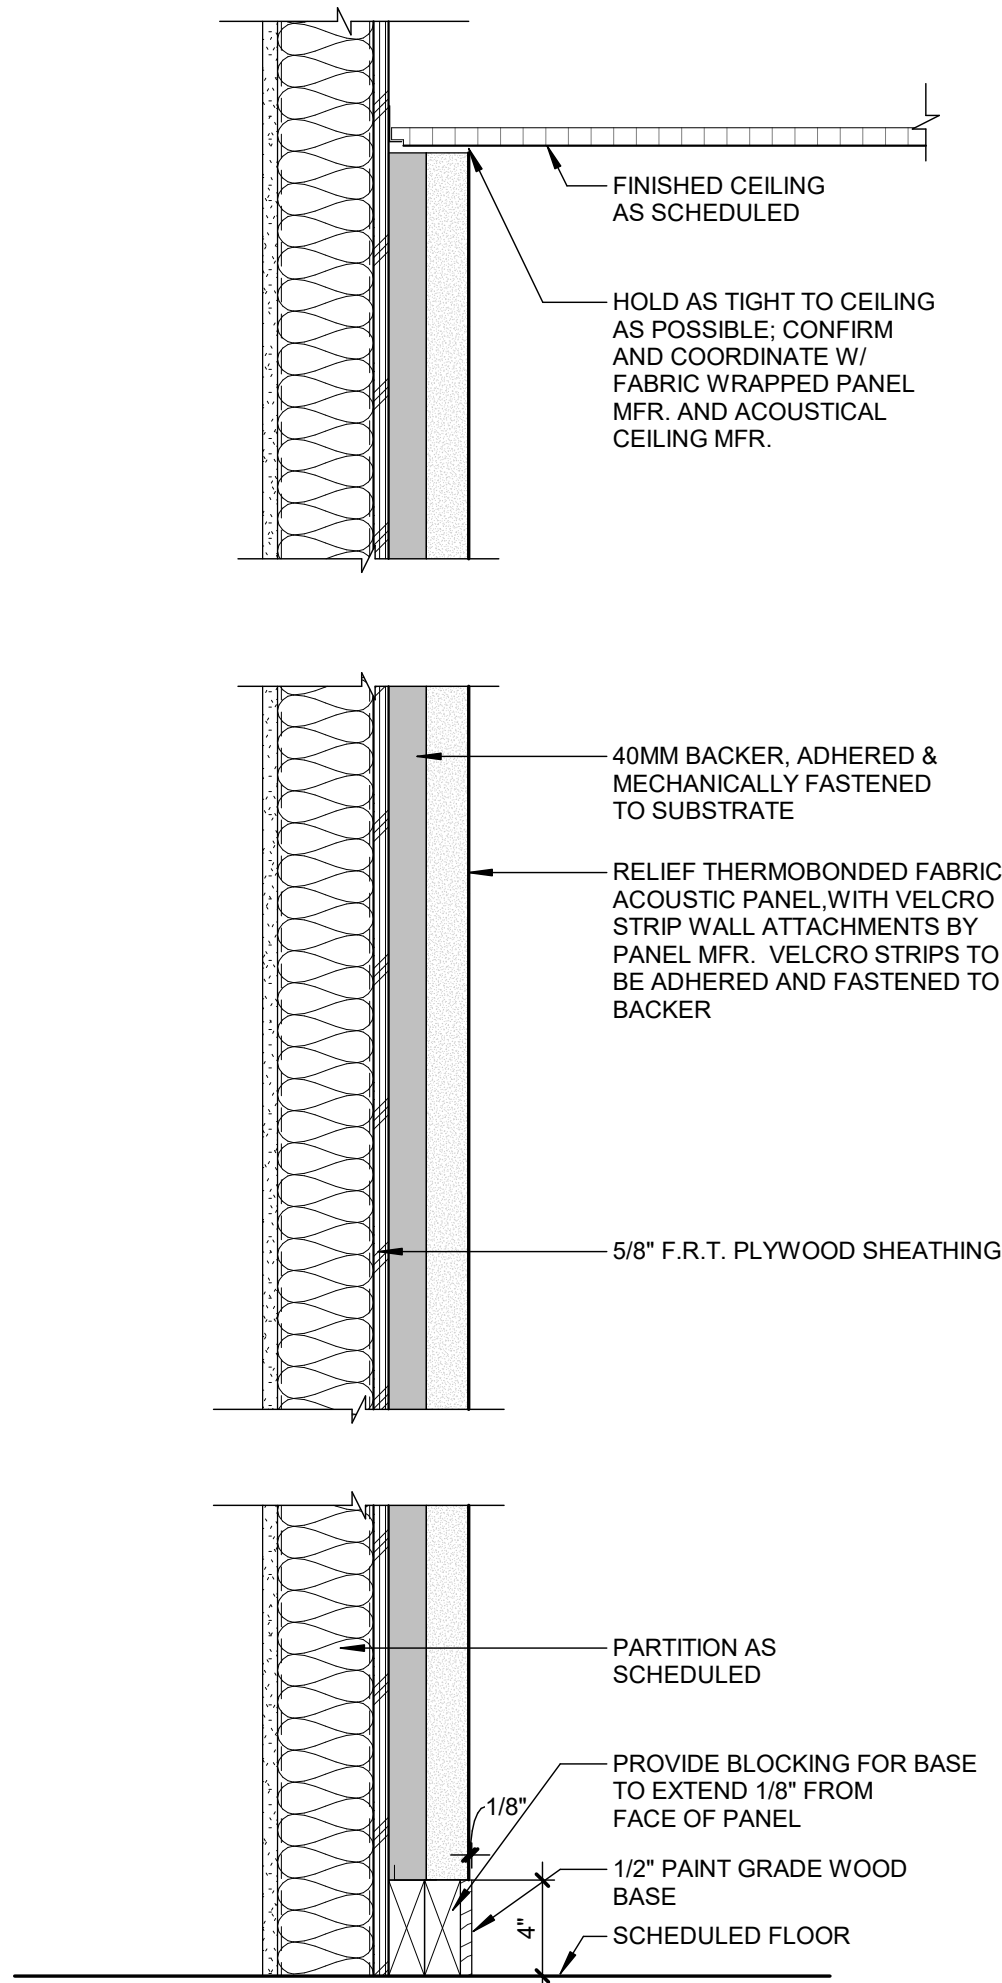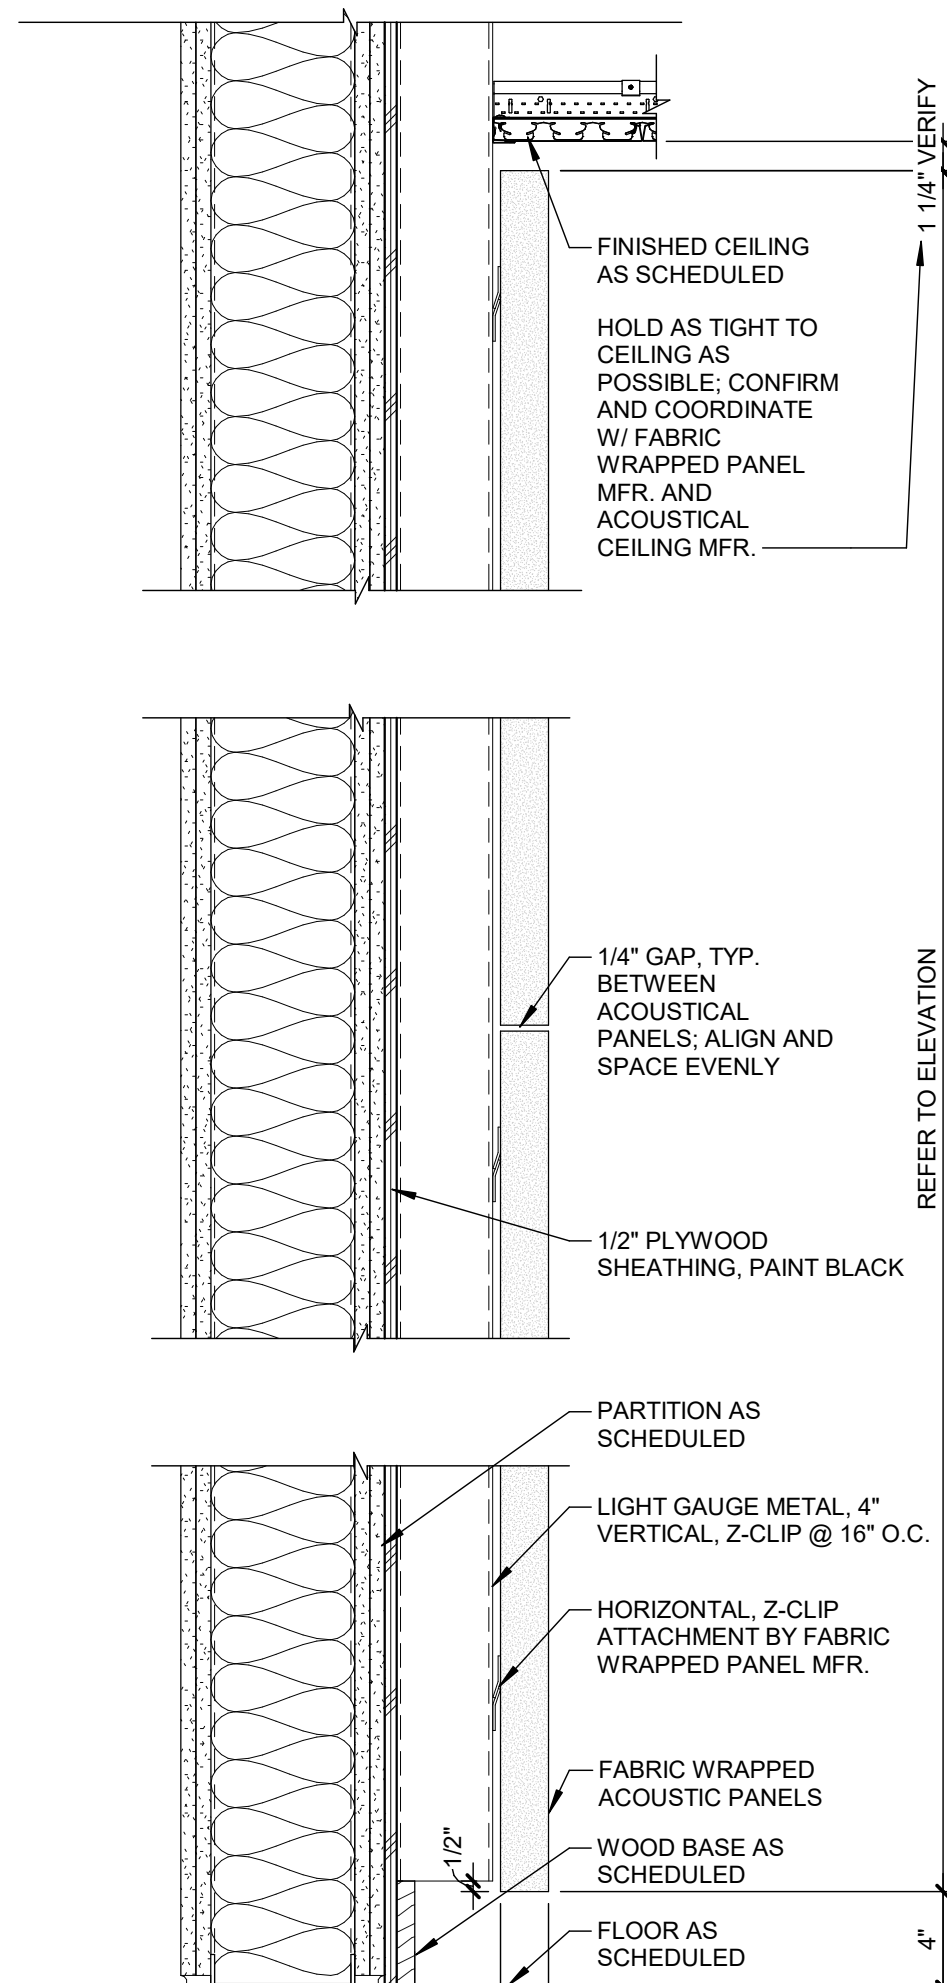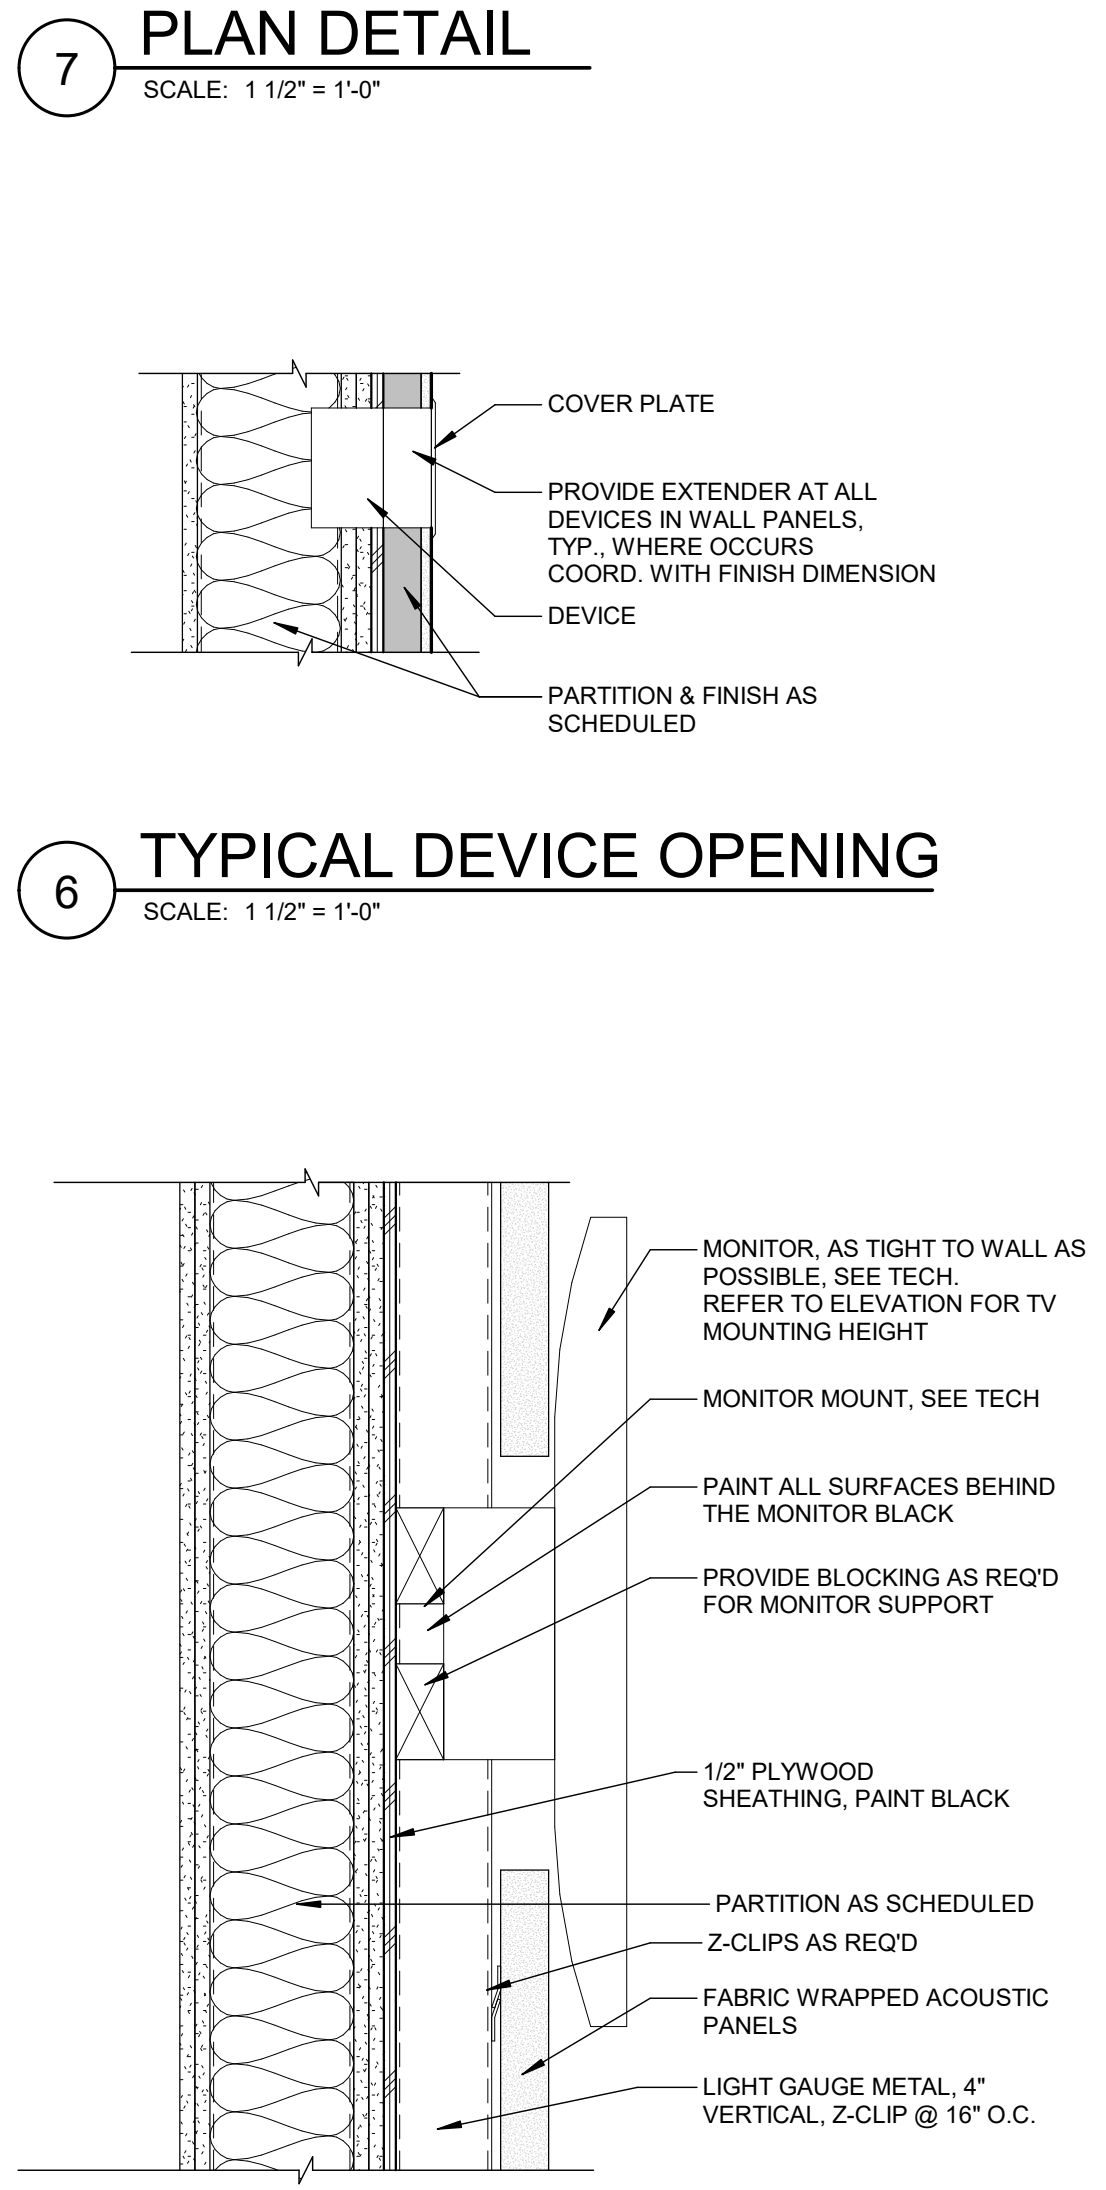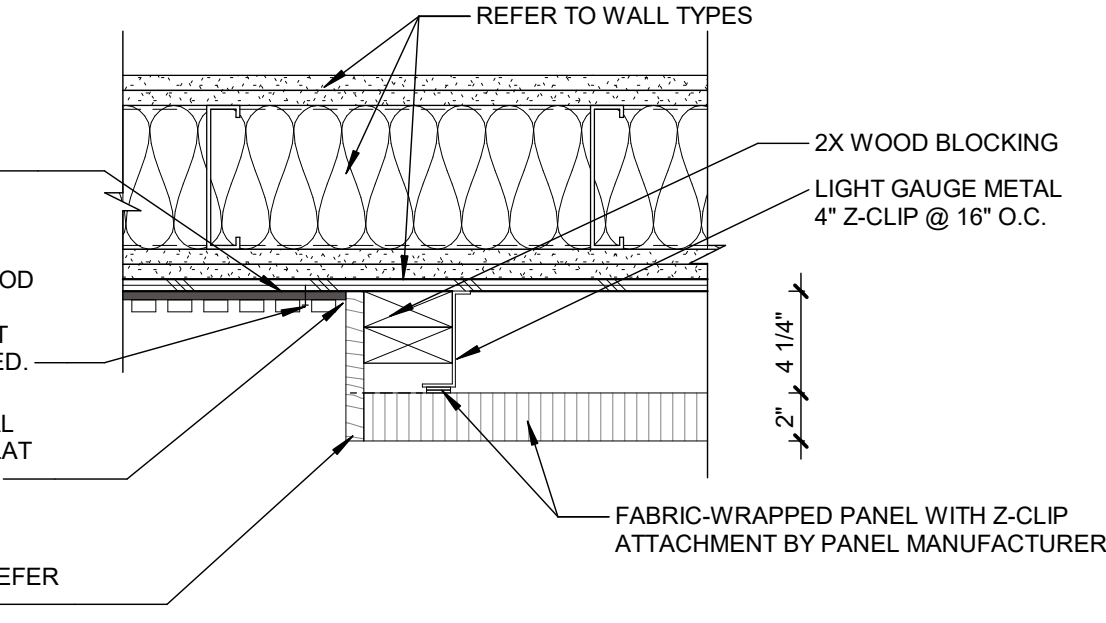

Van Buren Charter Township
Van Buren Township, MI
The Lakeside Park

REVISIONS		
10/27/2026	A2	ADDENDUM NO. 2


10/12/2026	BIDS & PERMIT
09/21/2026	CD PEER REVIEW
09/09/2026	CD TEAM REVIEW
08/10/2026	CD 50% PROGRESS
08/22/2026	DD OWNER REVIEW
06/15/2026	DD PEER REVIEW
06/08/2026	DD 90 % PROGRESS
05/18/2026	DD 50 % PROGRESS
02/23/2026	SD OWNER REVIEW
02/13/2026	SD PEER REVIEW
02/09/2026	SD PROGRESS REVIEW

Drawn By IOLKHOVESKA
Designer LFINNEY
Reviewer WLAPSON
Manager CKRETOVIC

Hard copy is intended to be 24"x36" when plotted. Scale(s) indicated and graphic quality may not be accurate for any other size.


PROJECT NO.
2500281
SHEET NO.

PLOT INFO: 10/27/2026 2:57:20 PM Autodesk Docs://2500281 - Van Buren Twp Lake House/2026_A_2500281.rvt

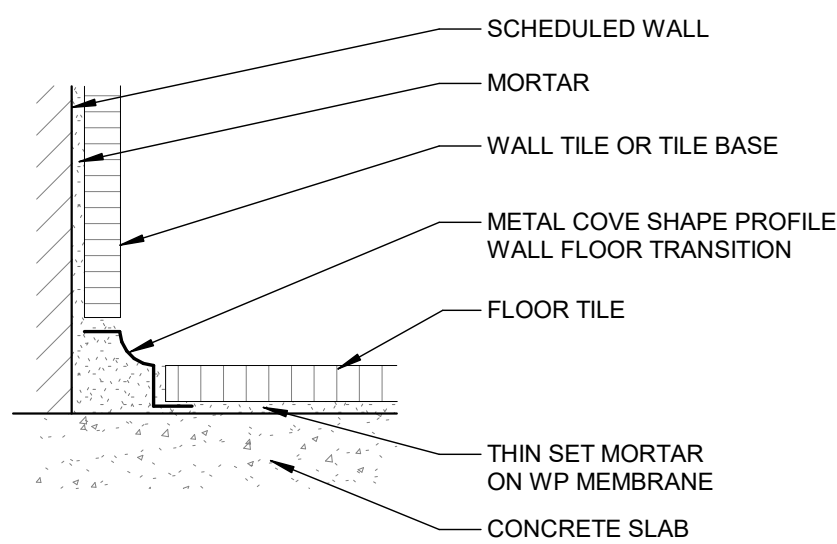


TYPICAL TILE COVE TRANSITION, TS3

4
SCALE: 6" = 1'-0"

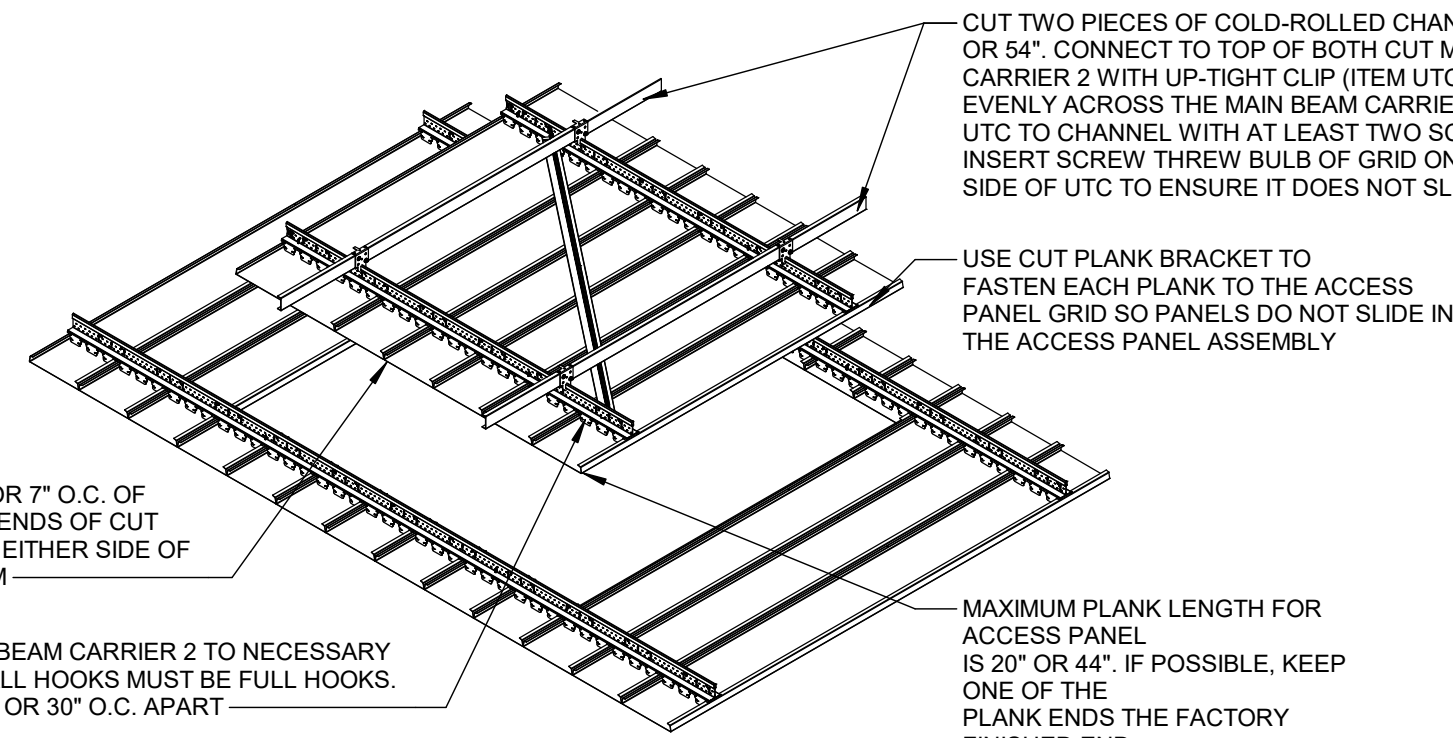


8
METAL PLANK CEILING ACCESS PANEL
TYPICAL DETAIL
SCALE: NOT TO SCALE

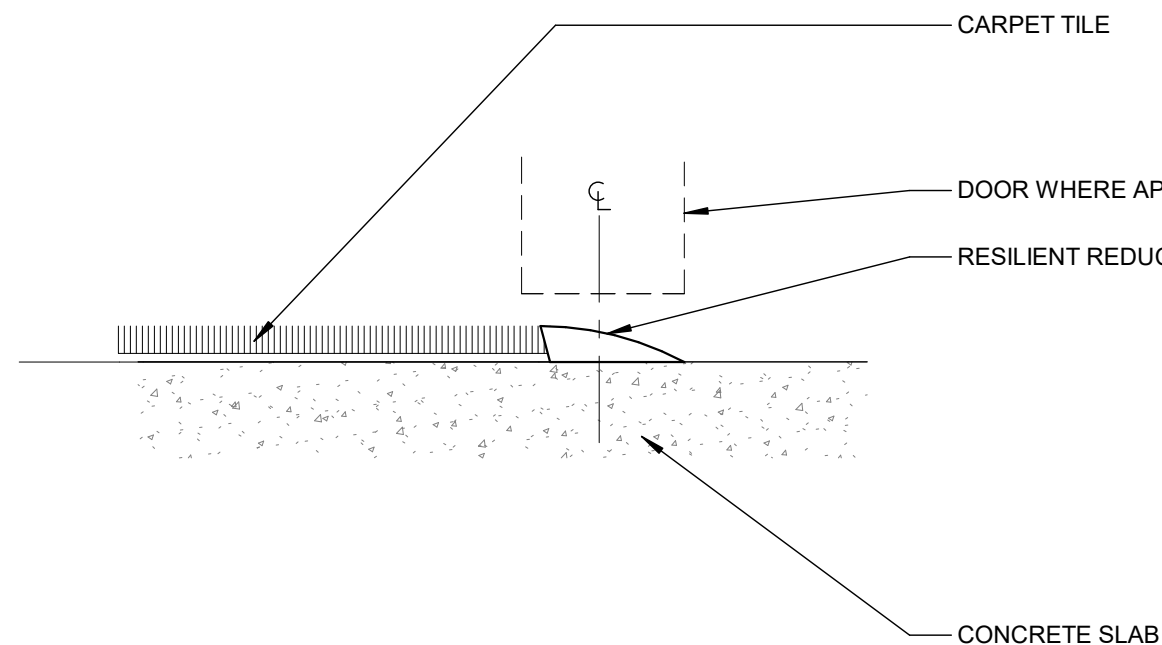


TYPICAL CPT/CONC TRANSITION, TS5

3
SCALE: 6" = 1'-0"

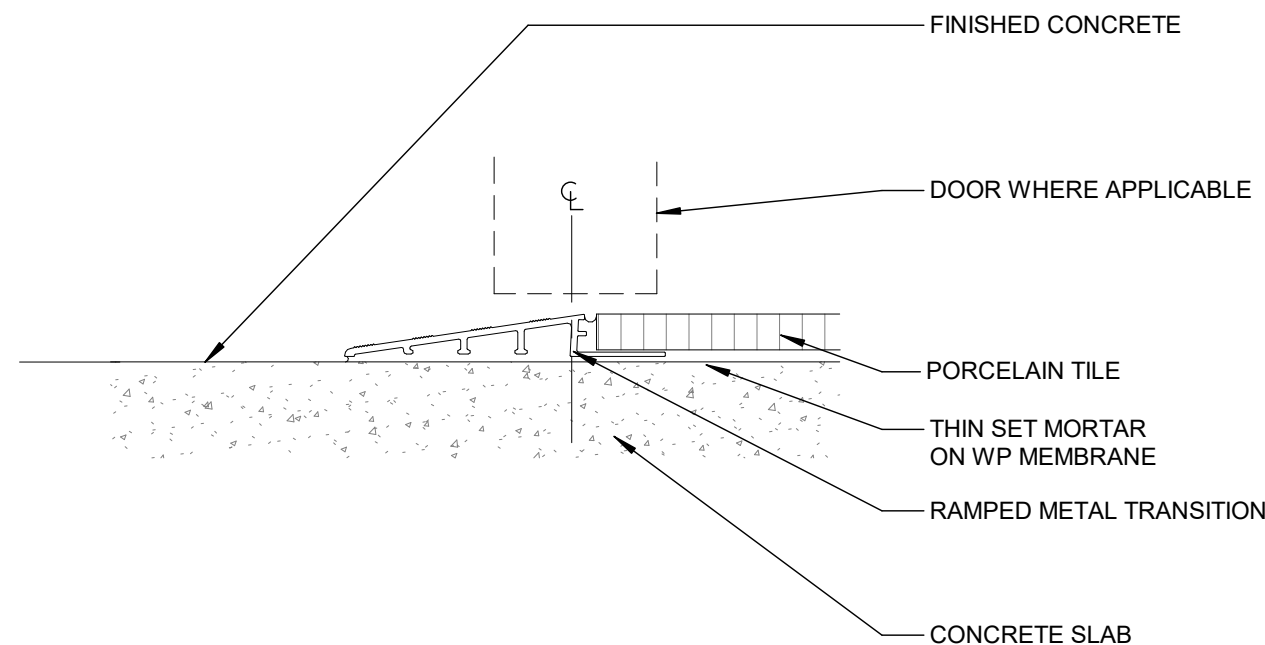


TYPICAL TILE/CONC TRANSITION, TS4

2
SCALE: 6" = 1'-0"

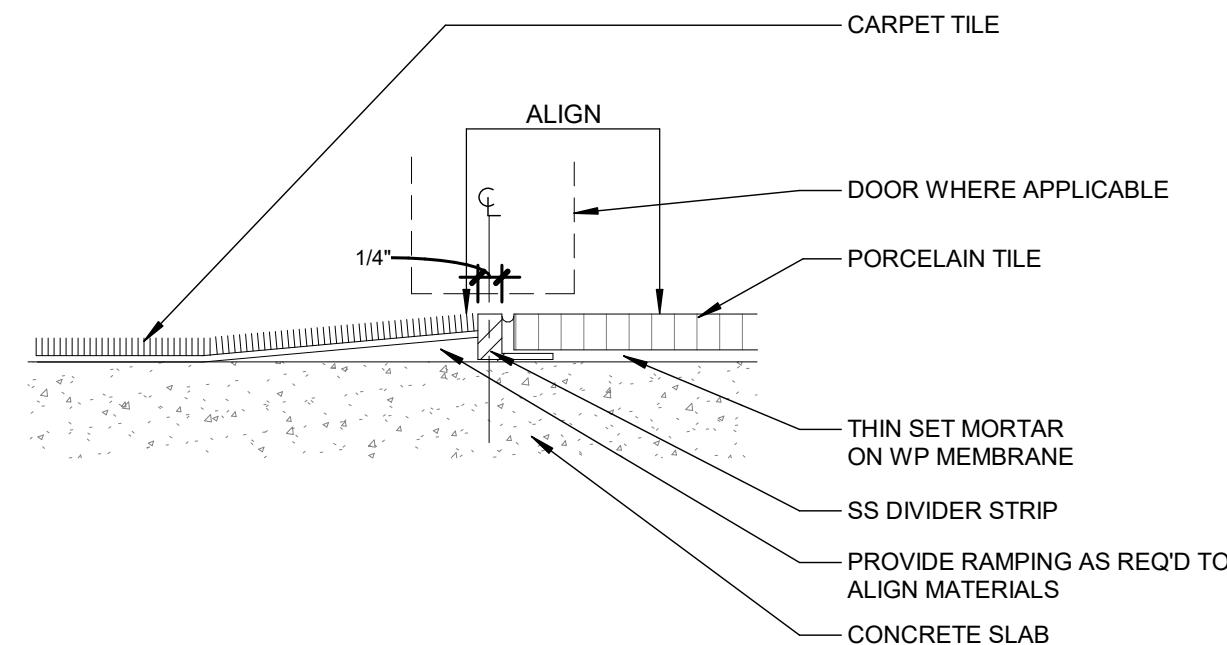


TYPICAL TILE/CARPET OR VCT TRANSITION, TS1


1
SCALE: 6" = 1'-0"

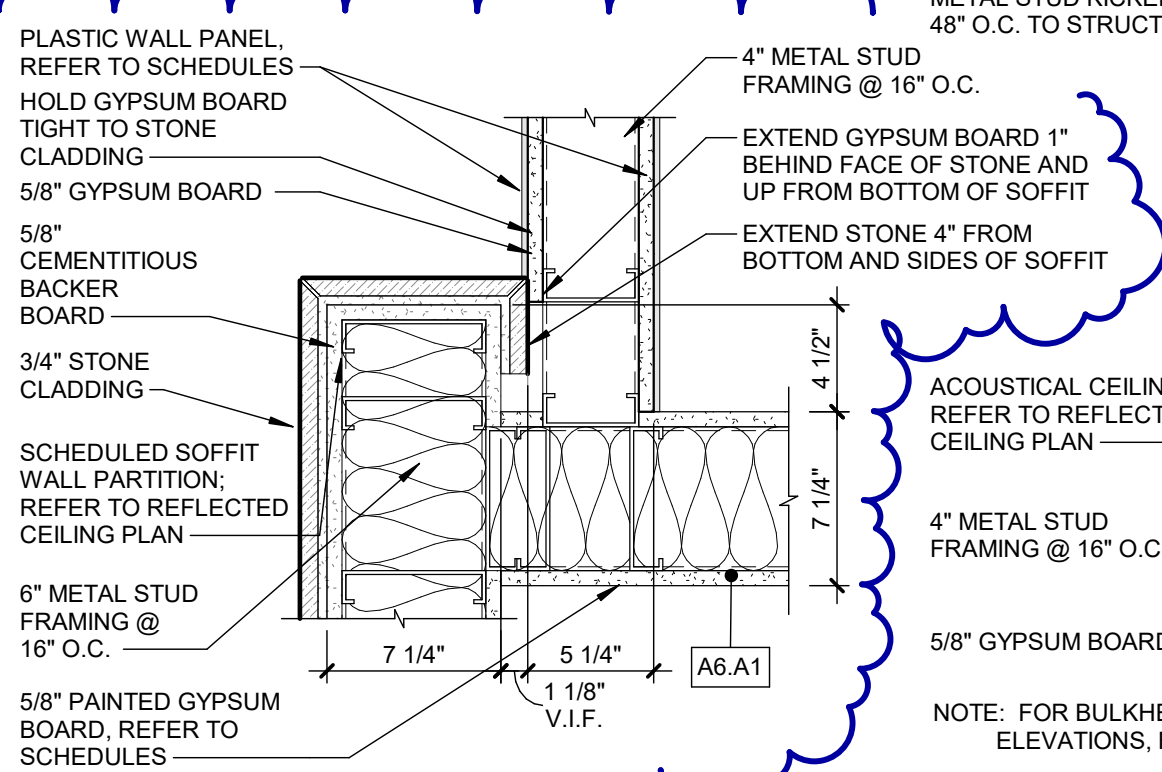


7
PLAN DETAIL
SCALE: 1 1/2" = 1'-0"

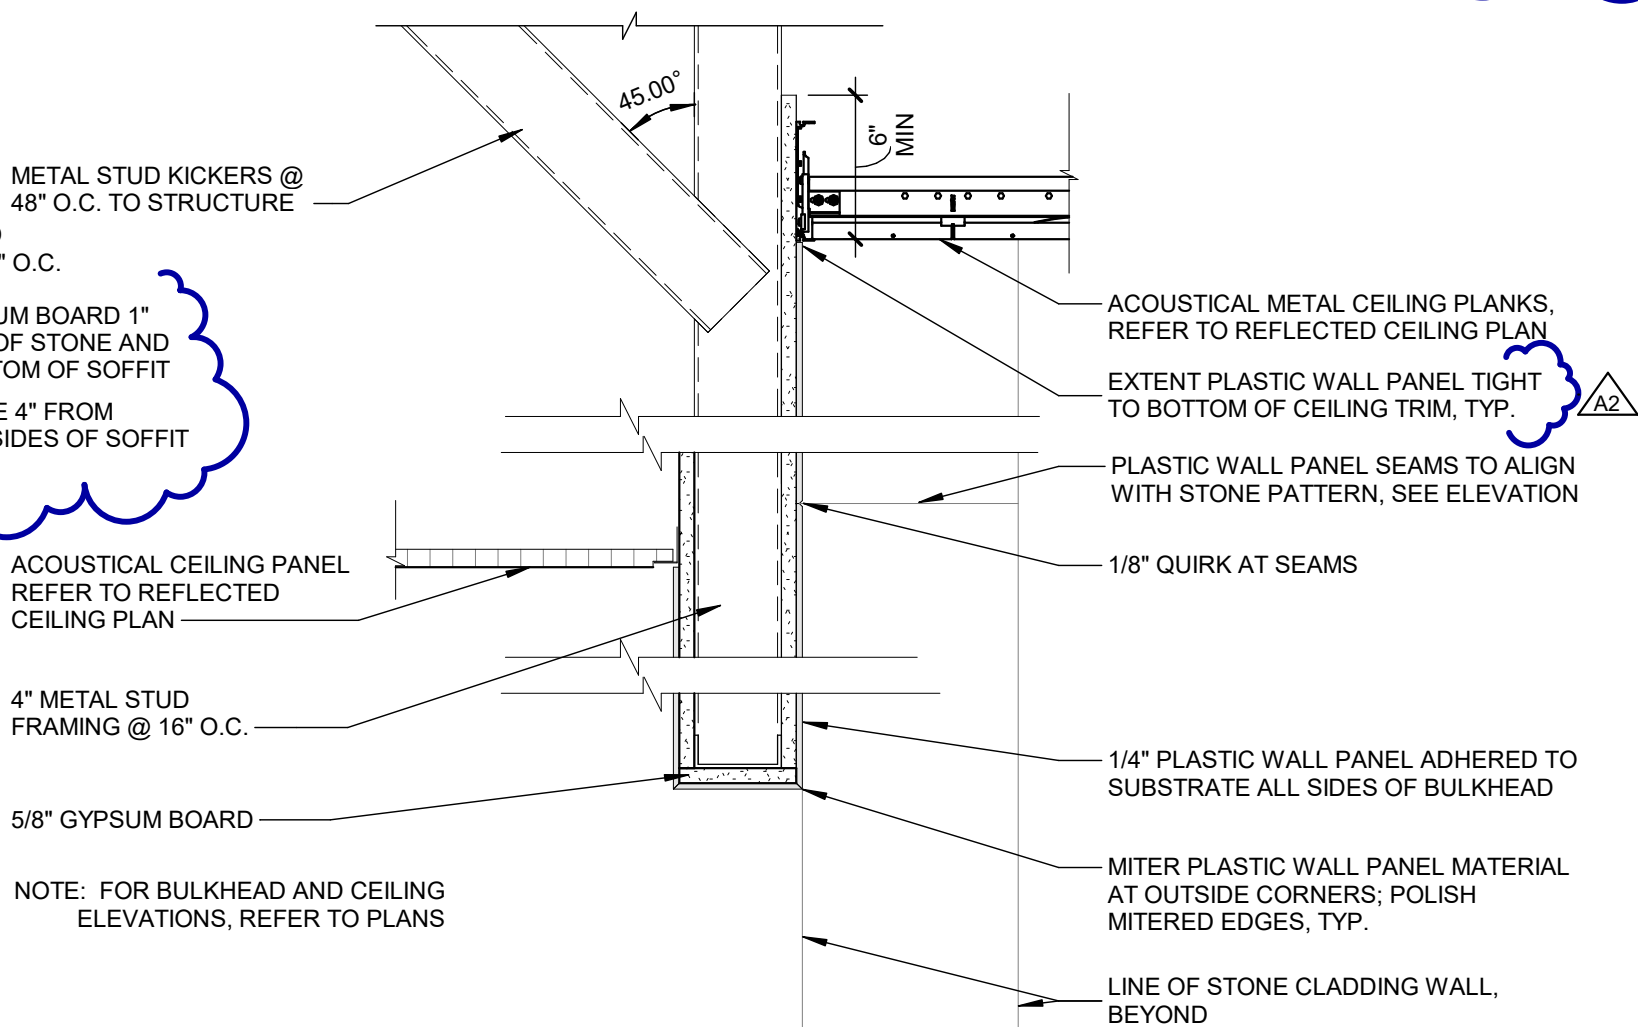



6
SECTION DETAIL
SCALE: 1 1/2" = 1'-0"

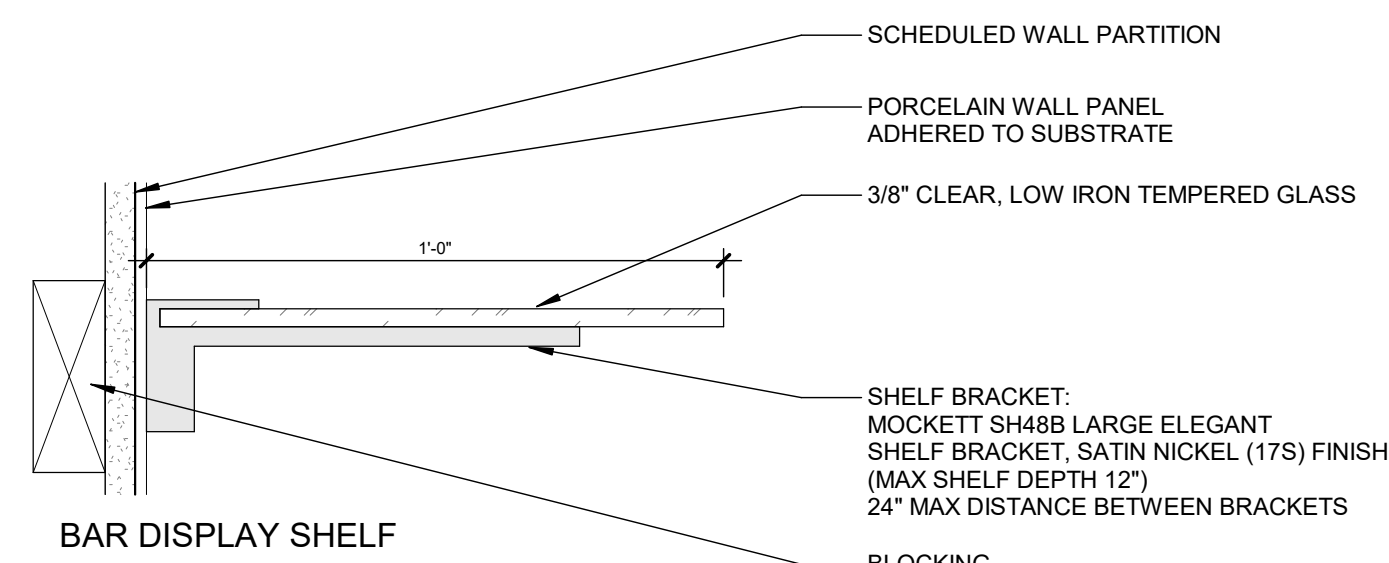


5
BAR DISPLAY SHELF
SECTION DETAIL
SCALE: 3" = 1'-0"

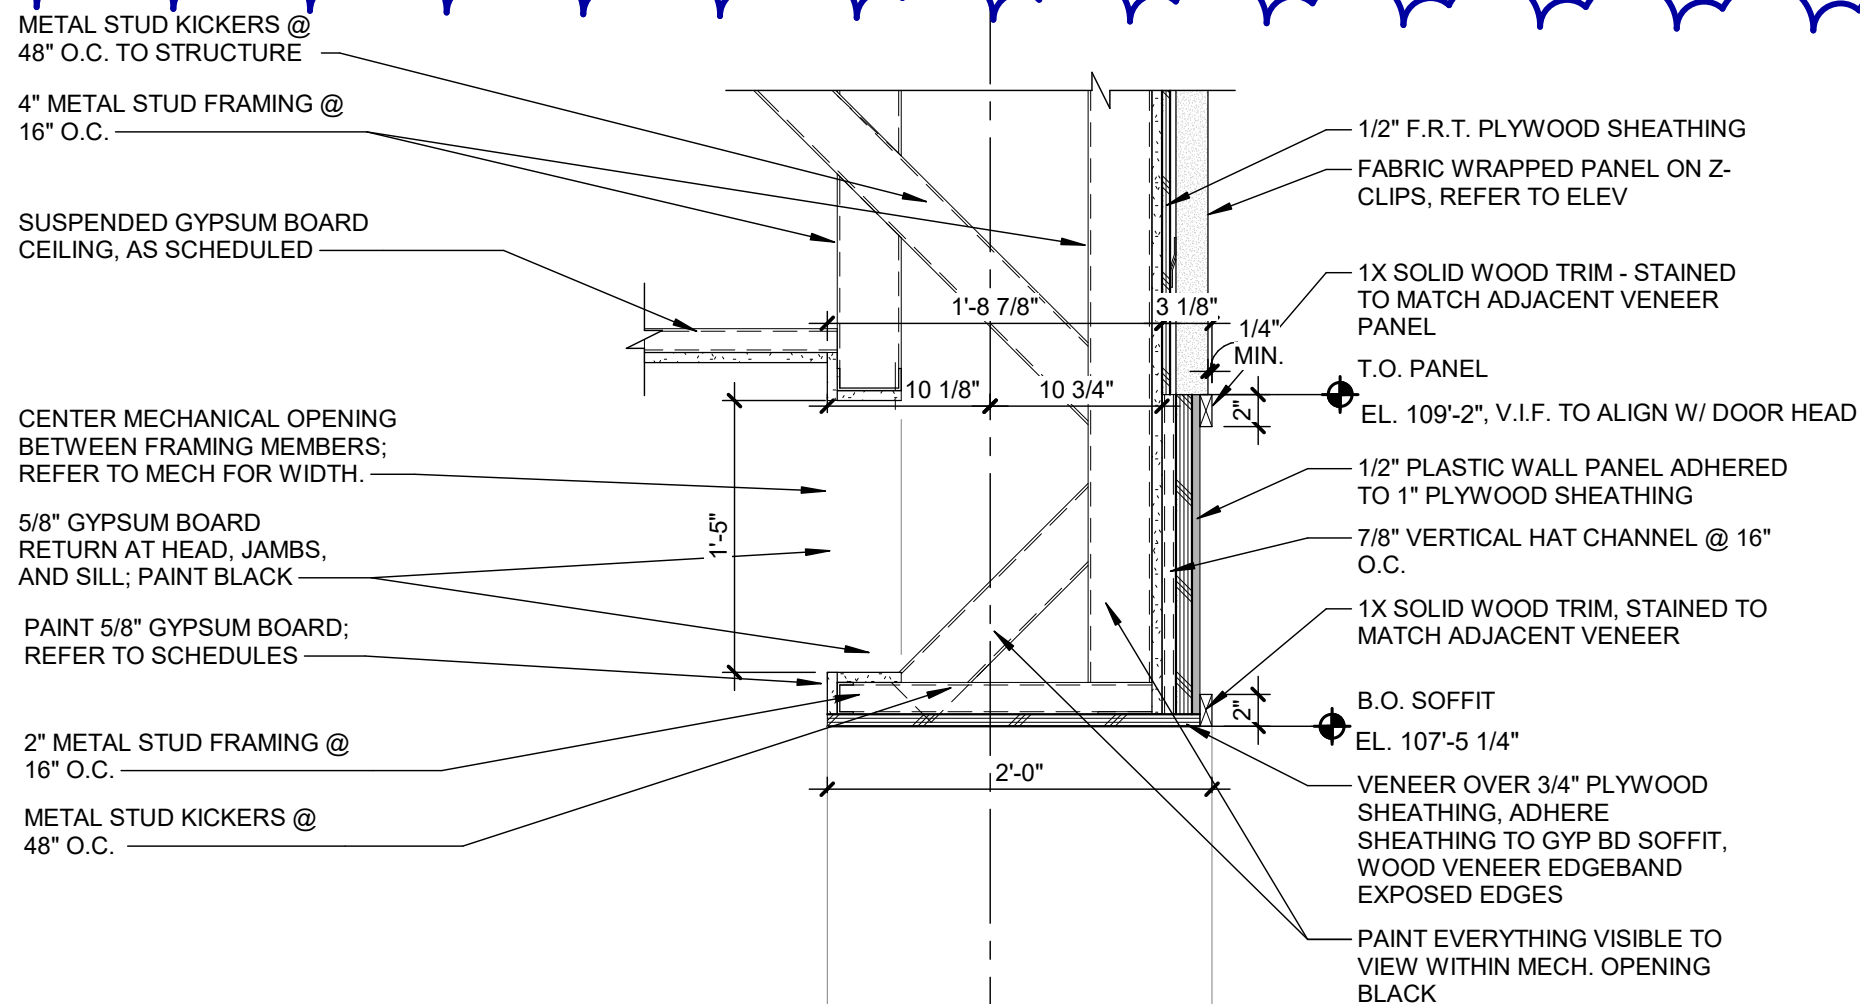


11
MILLWORK SECTION
SCALE: 1" = 1'-0"

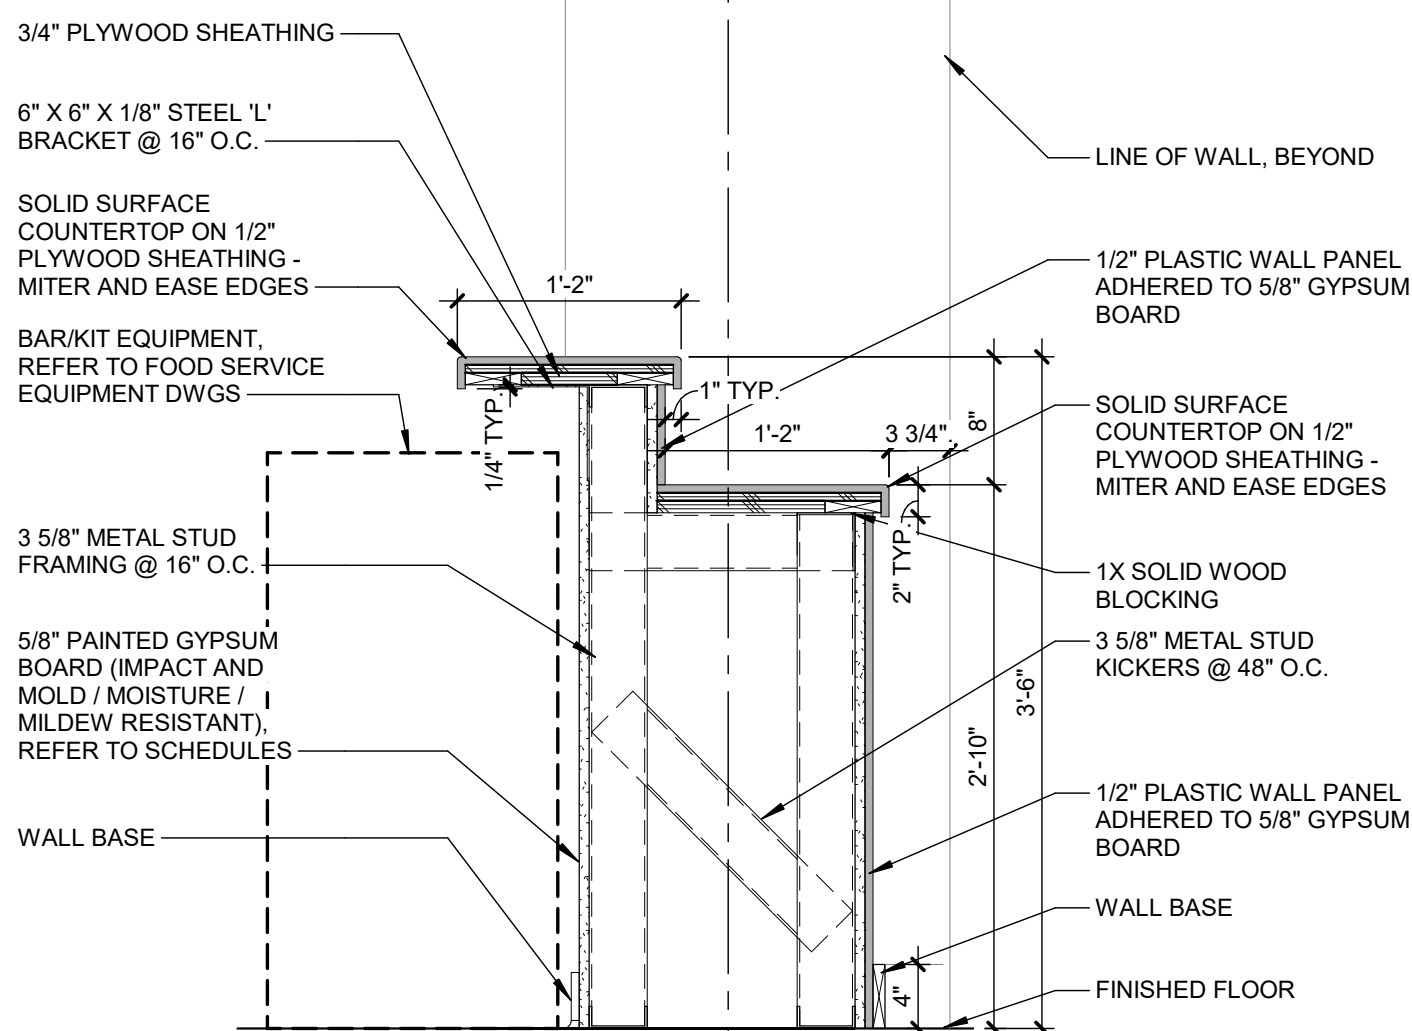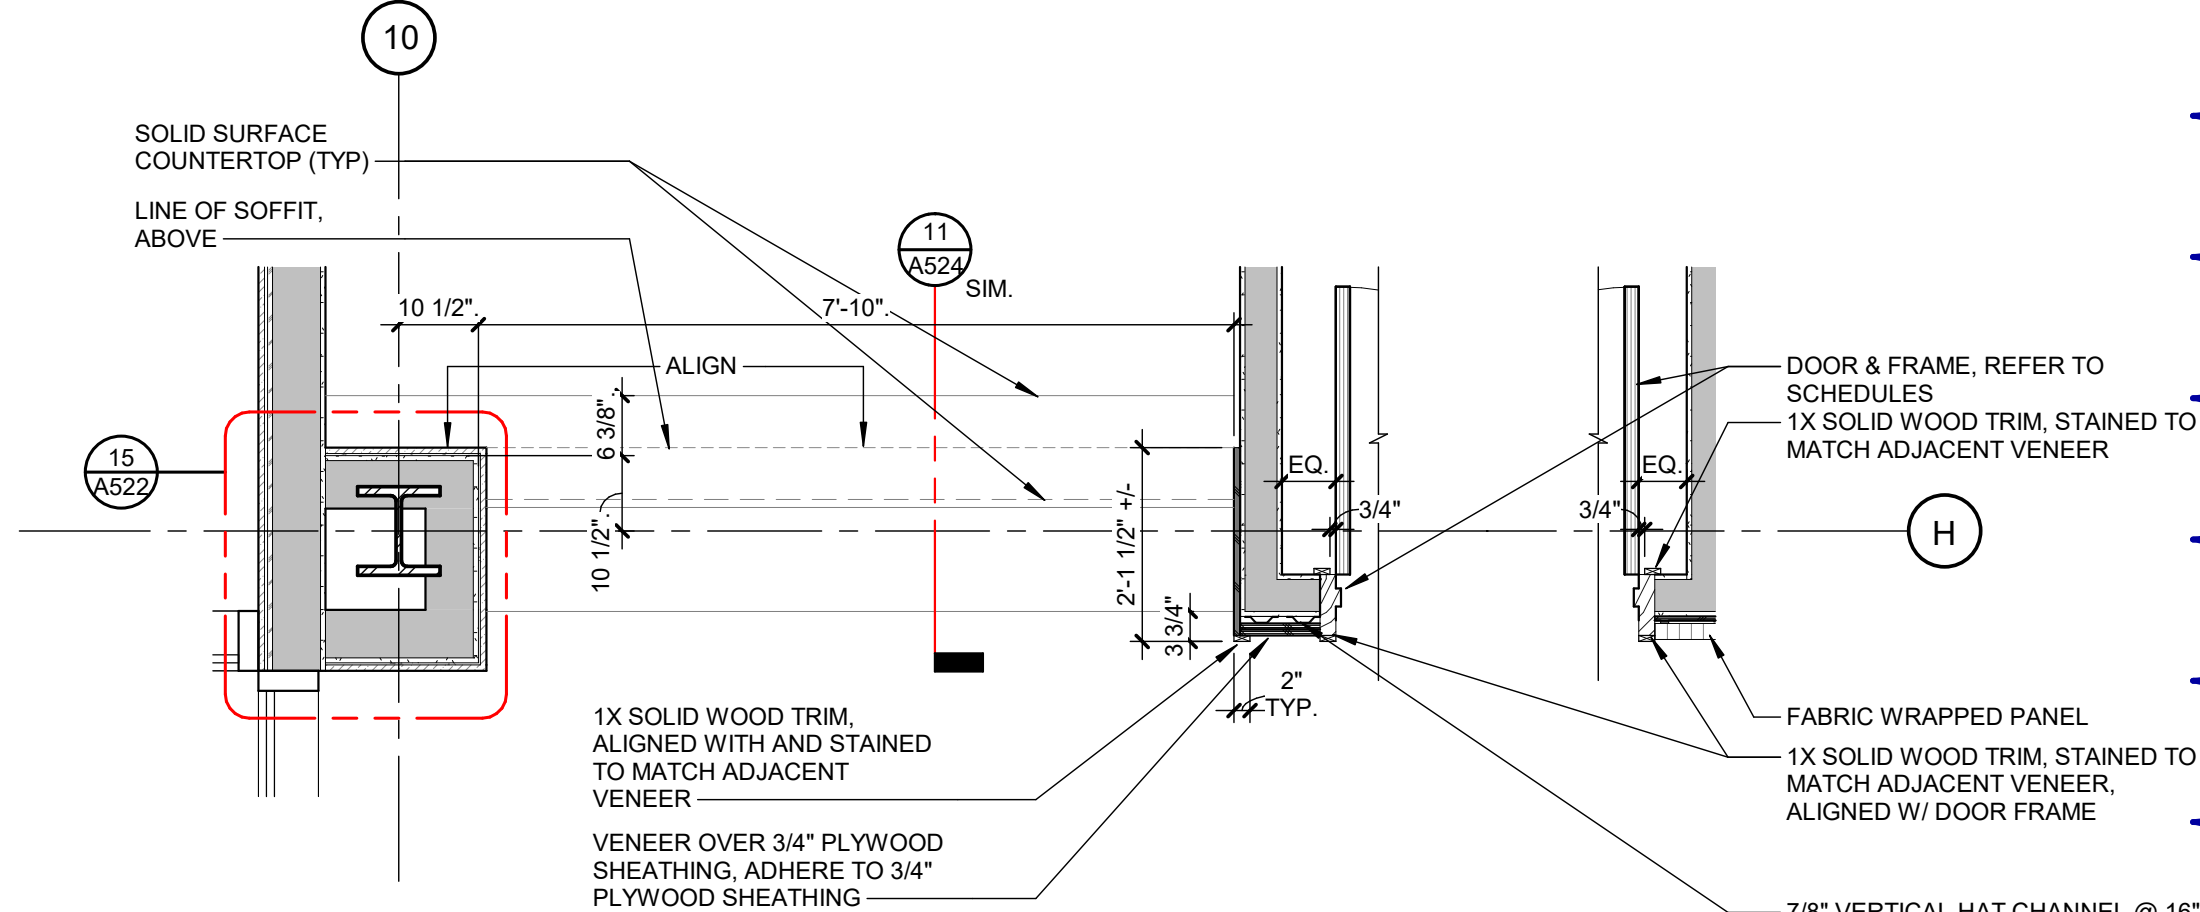


13
LAKE HALL BAR 167
ENLARGED PLAN
SCALE: 1/2" = 1'-0"

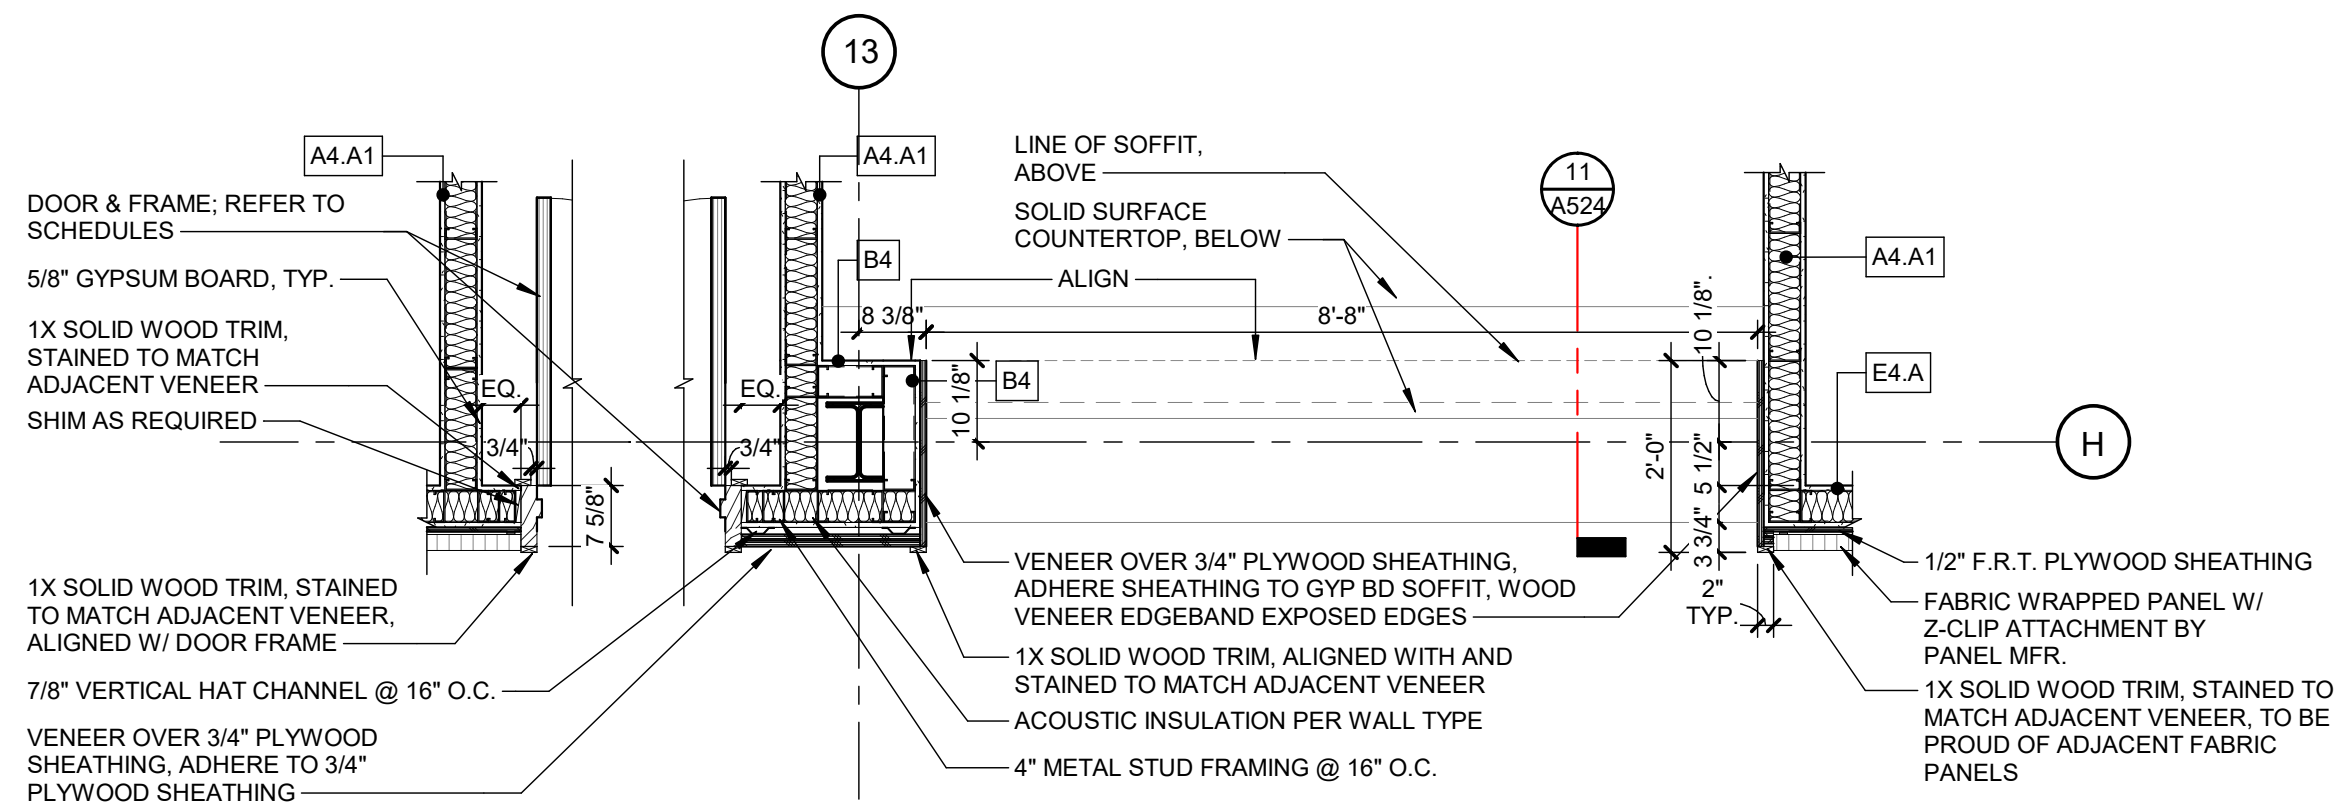

10
LAKE HALL BAR 165
ENLARGED PLAN
SCALE: 1/2" = 1'-0"

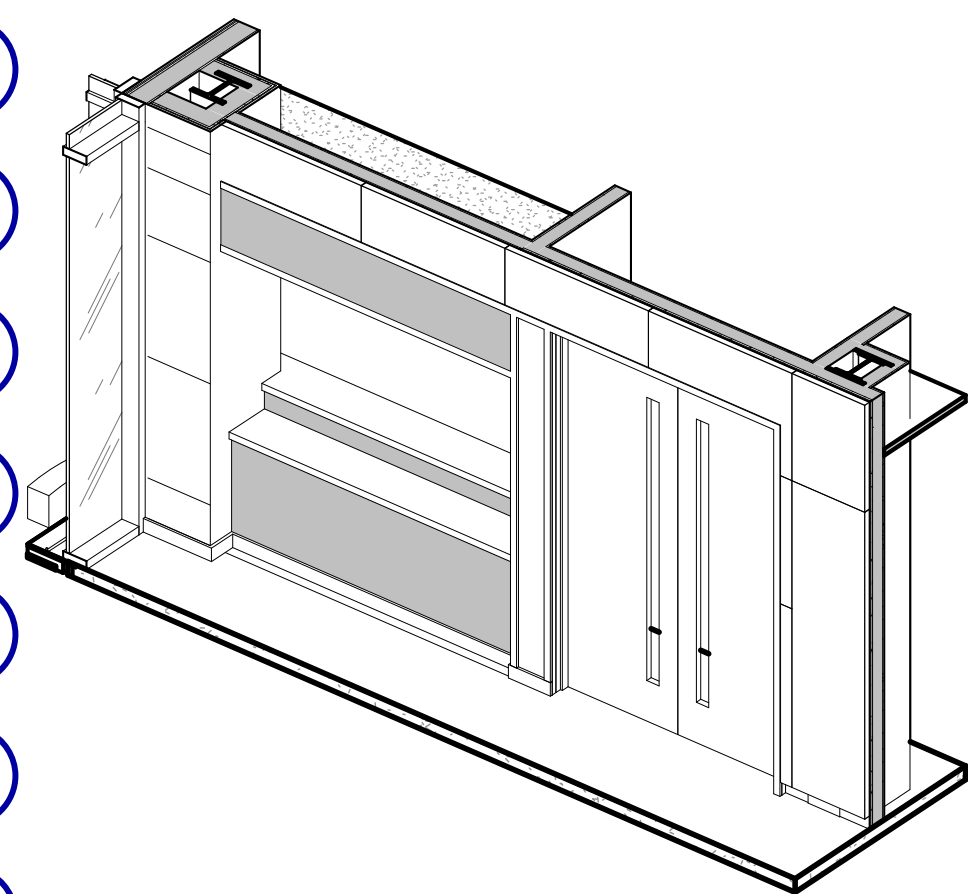

12
BAR 167 - ISO
SCALE:

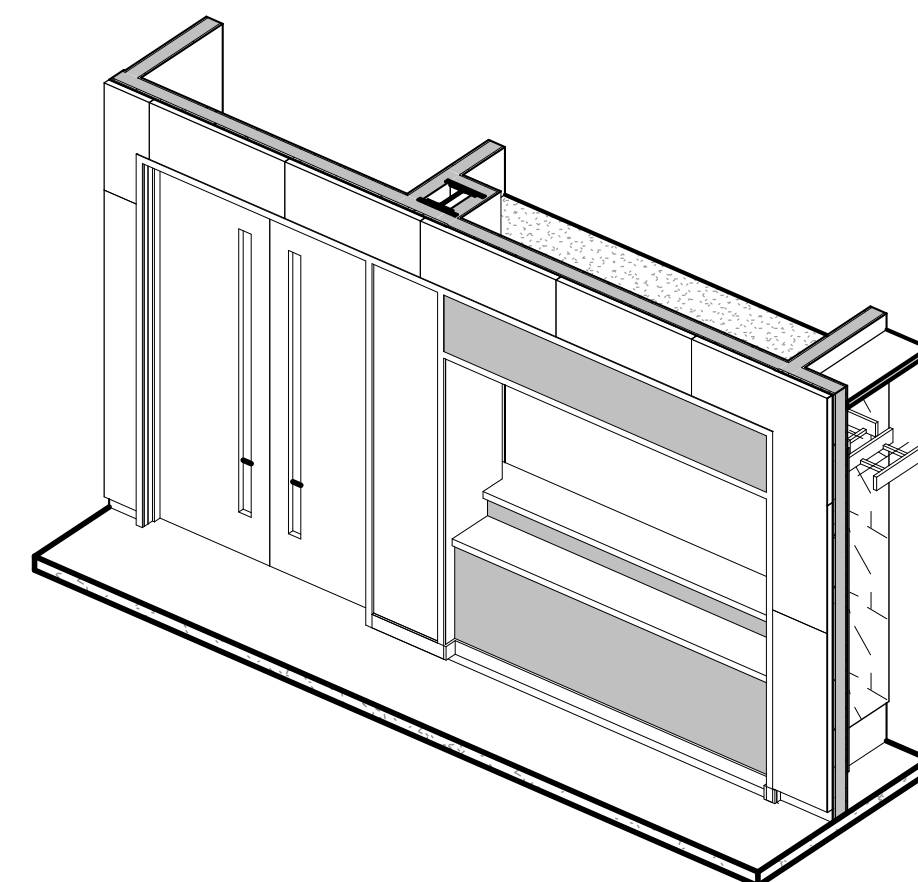

9
BAR 165 - ISO
SCALE:

Van Buren Charter Township

Van Buren Township, MI

The Lakeside Park

fishbeck
Engineers | Architects | Scientists | Constructors

REVISIONS		
10/27/2026	A2	ADDENDUM NO. 2

10/12/2026	BIDS & PERMIT
09/21/2026	CD PEER REVIEW
09/09/2026	CD TEAM REVIEW
08/10/2026	CD 50% PROGRESS
08/22/2026	DD OWNER REVIEW
06/15/2026	DD PEER REVIEW
06/08/2026	DD 90% PROGRESS
05/18/2026	DD 90% PROGRESS
02/23/2026	SD OWNER REVIEW
02/13/2026	SD PEER REVIEW
02/09/2026	SD PROGRESS REVIEW

Drawn By IOLKHOVESKA
Designer LFINNEY
Reviewer WLRAPSON
Manager CKRETOVIC

Hard copy is intended to be 24"x36" when plotted. Scale(s) indicated and graphic quality may not be accurate for any other size.


PROJECT NO.
2500281

SHEET NO.

A524

©Copyright 2026
All Rights Reserved


PLOT INFO: 10/27/2026 2:57:21 PM Autodesk Docs://2500281 - Van Buren Twp Lake House/2026_A_2500281.rvt

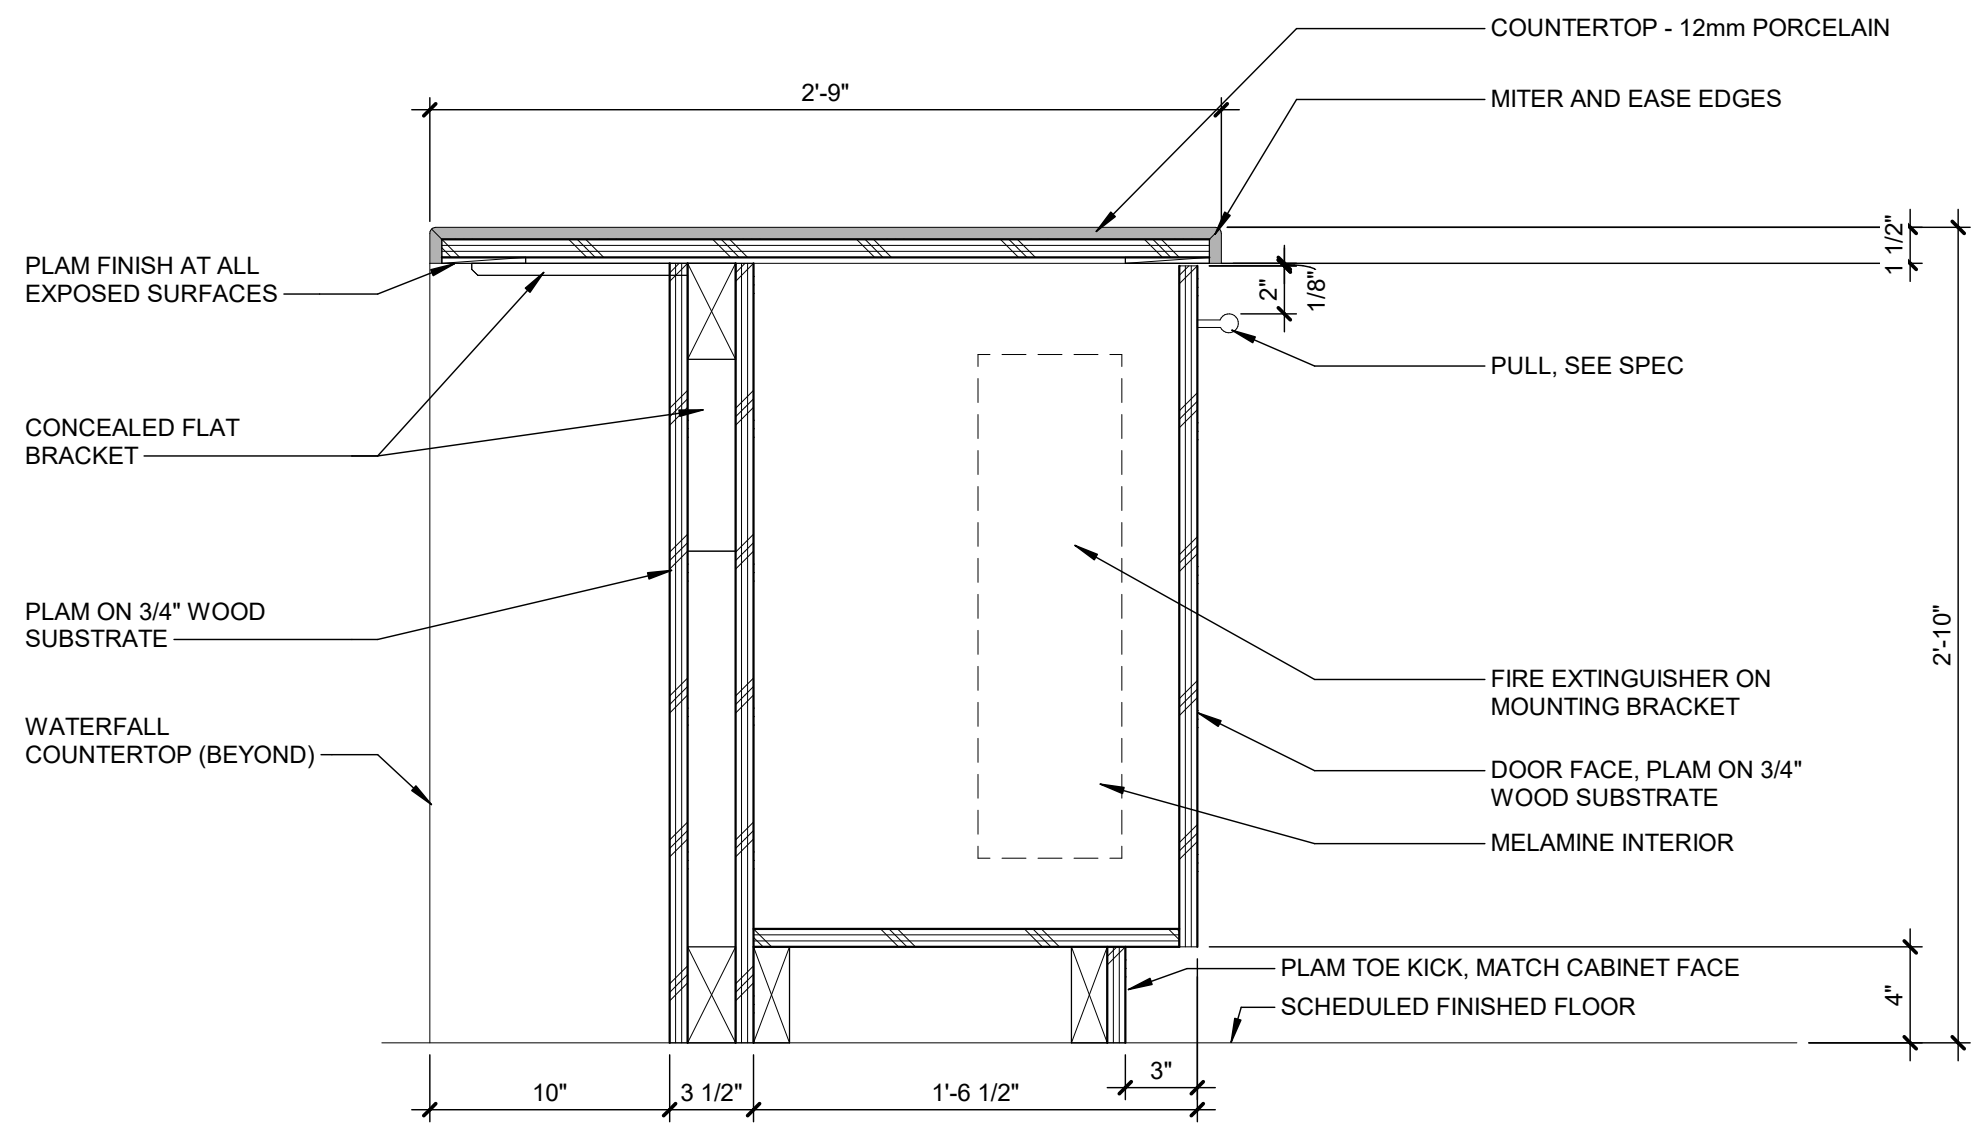

BASE CABINET AT ISLAND - FIRE EXTINGUISHER

CASEWORK SECTION DETAIL


SCALE: 1 1/2" = 1'-0"

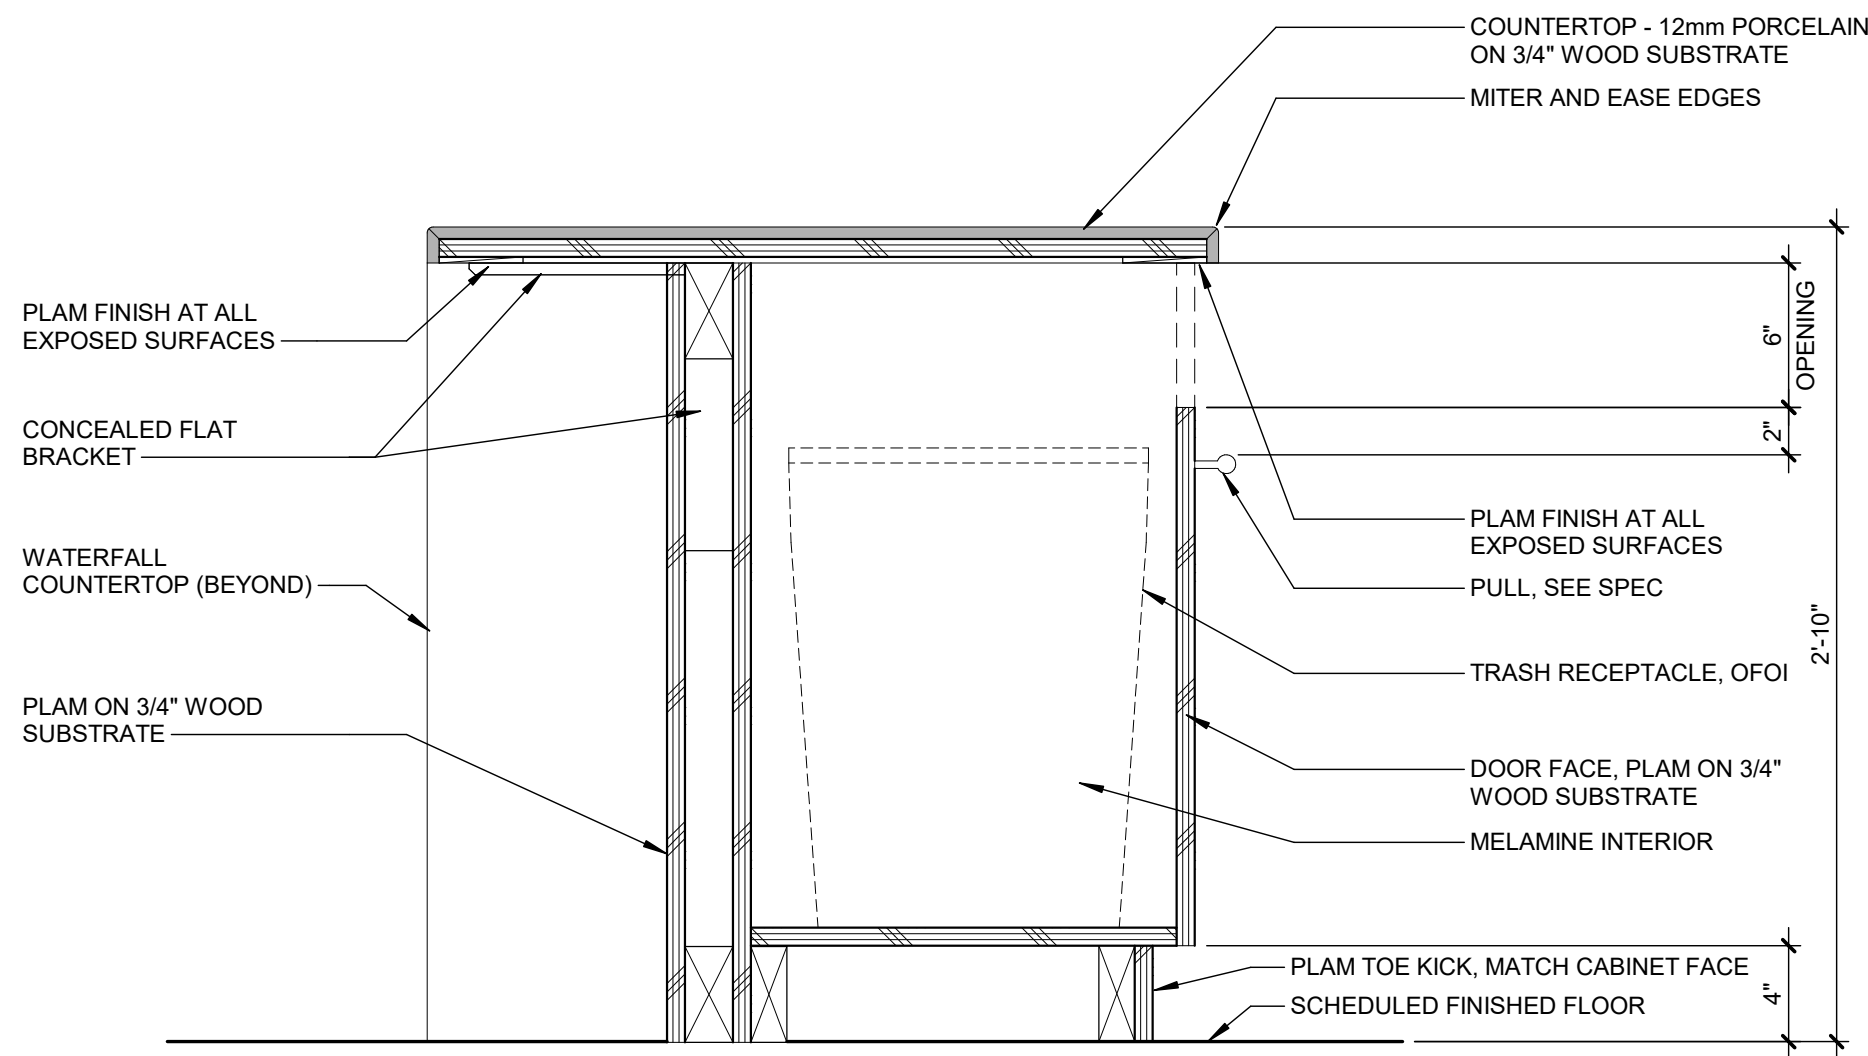

BASE CABINET AT ISLAND - WASTE

CASEWORK SECTION DETAIL


SCALE: 1 1/2" = 1'-0"

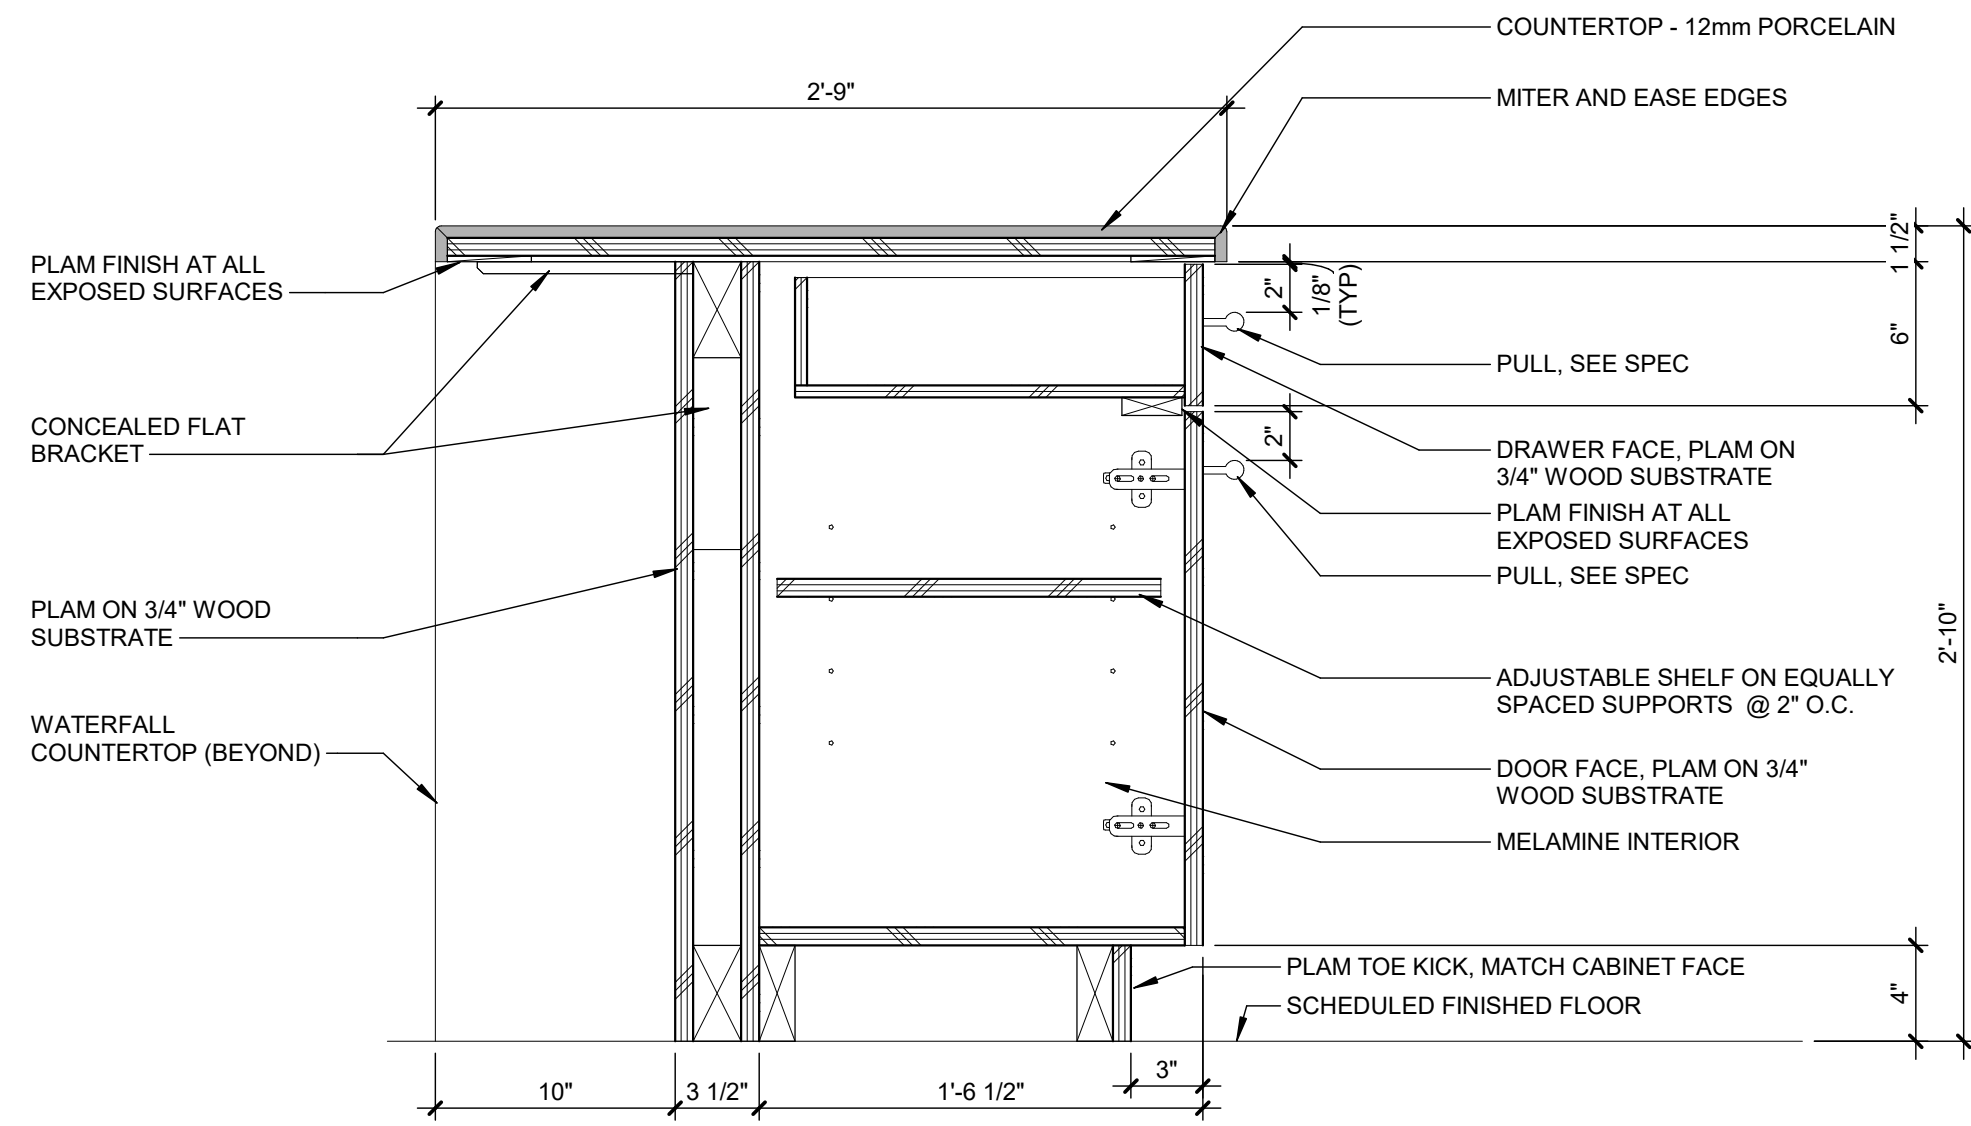

BASE CABINET AT ISLAND - TYPICAL DOOR/DRAWER

CASEWORK SECTION DETAIL


SCALE: 1 1/2" = 1'-0"

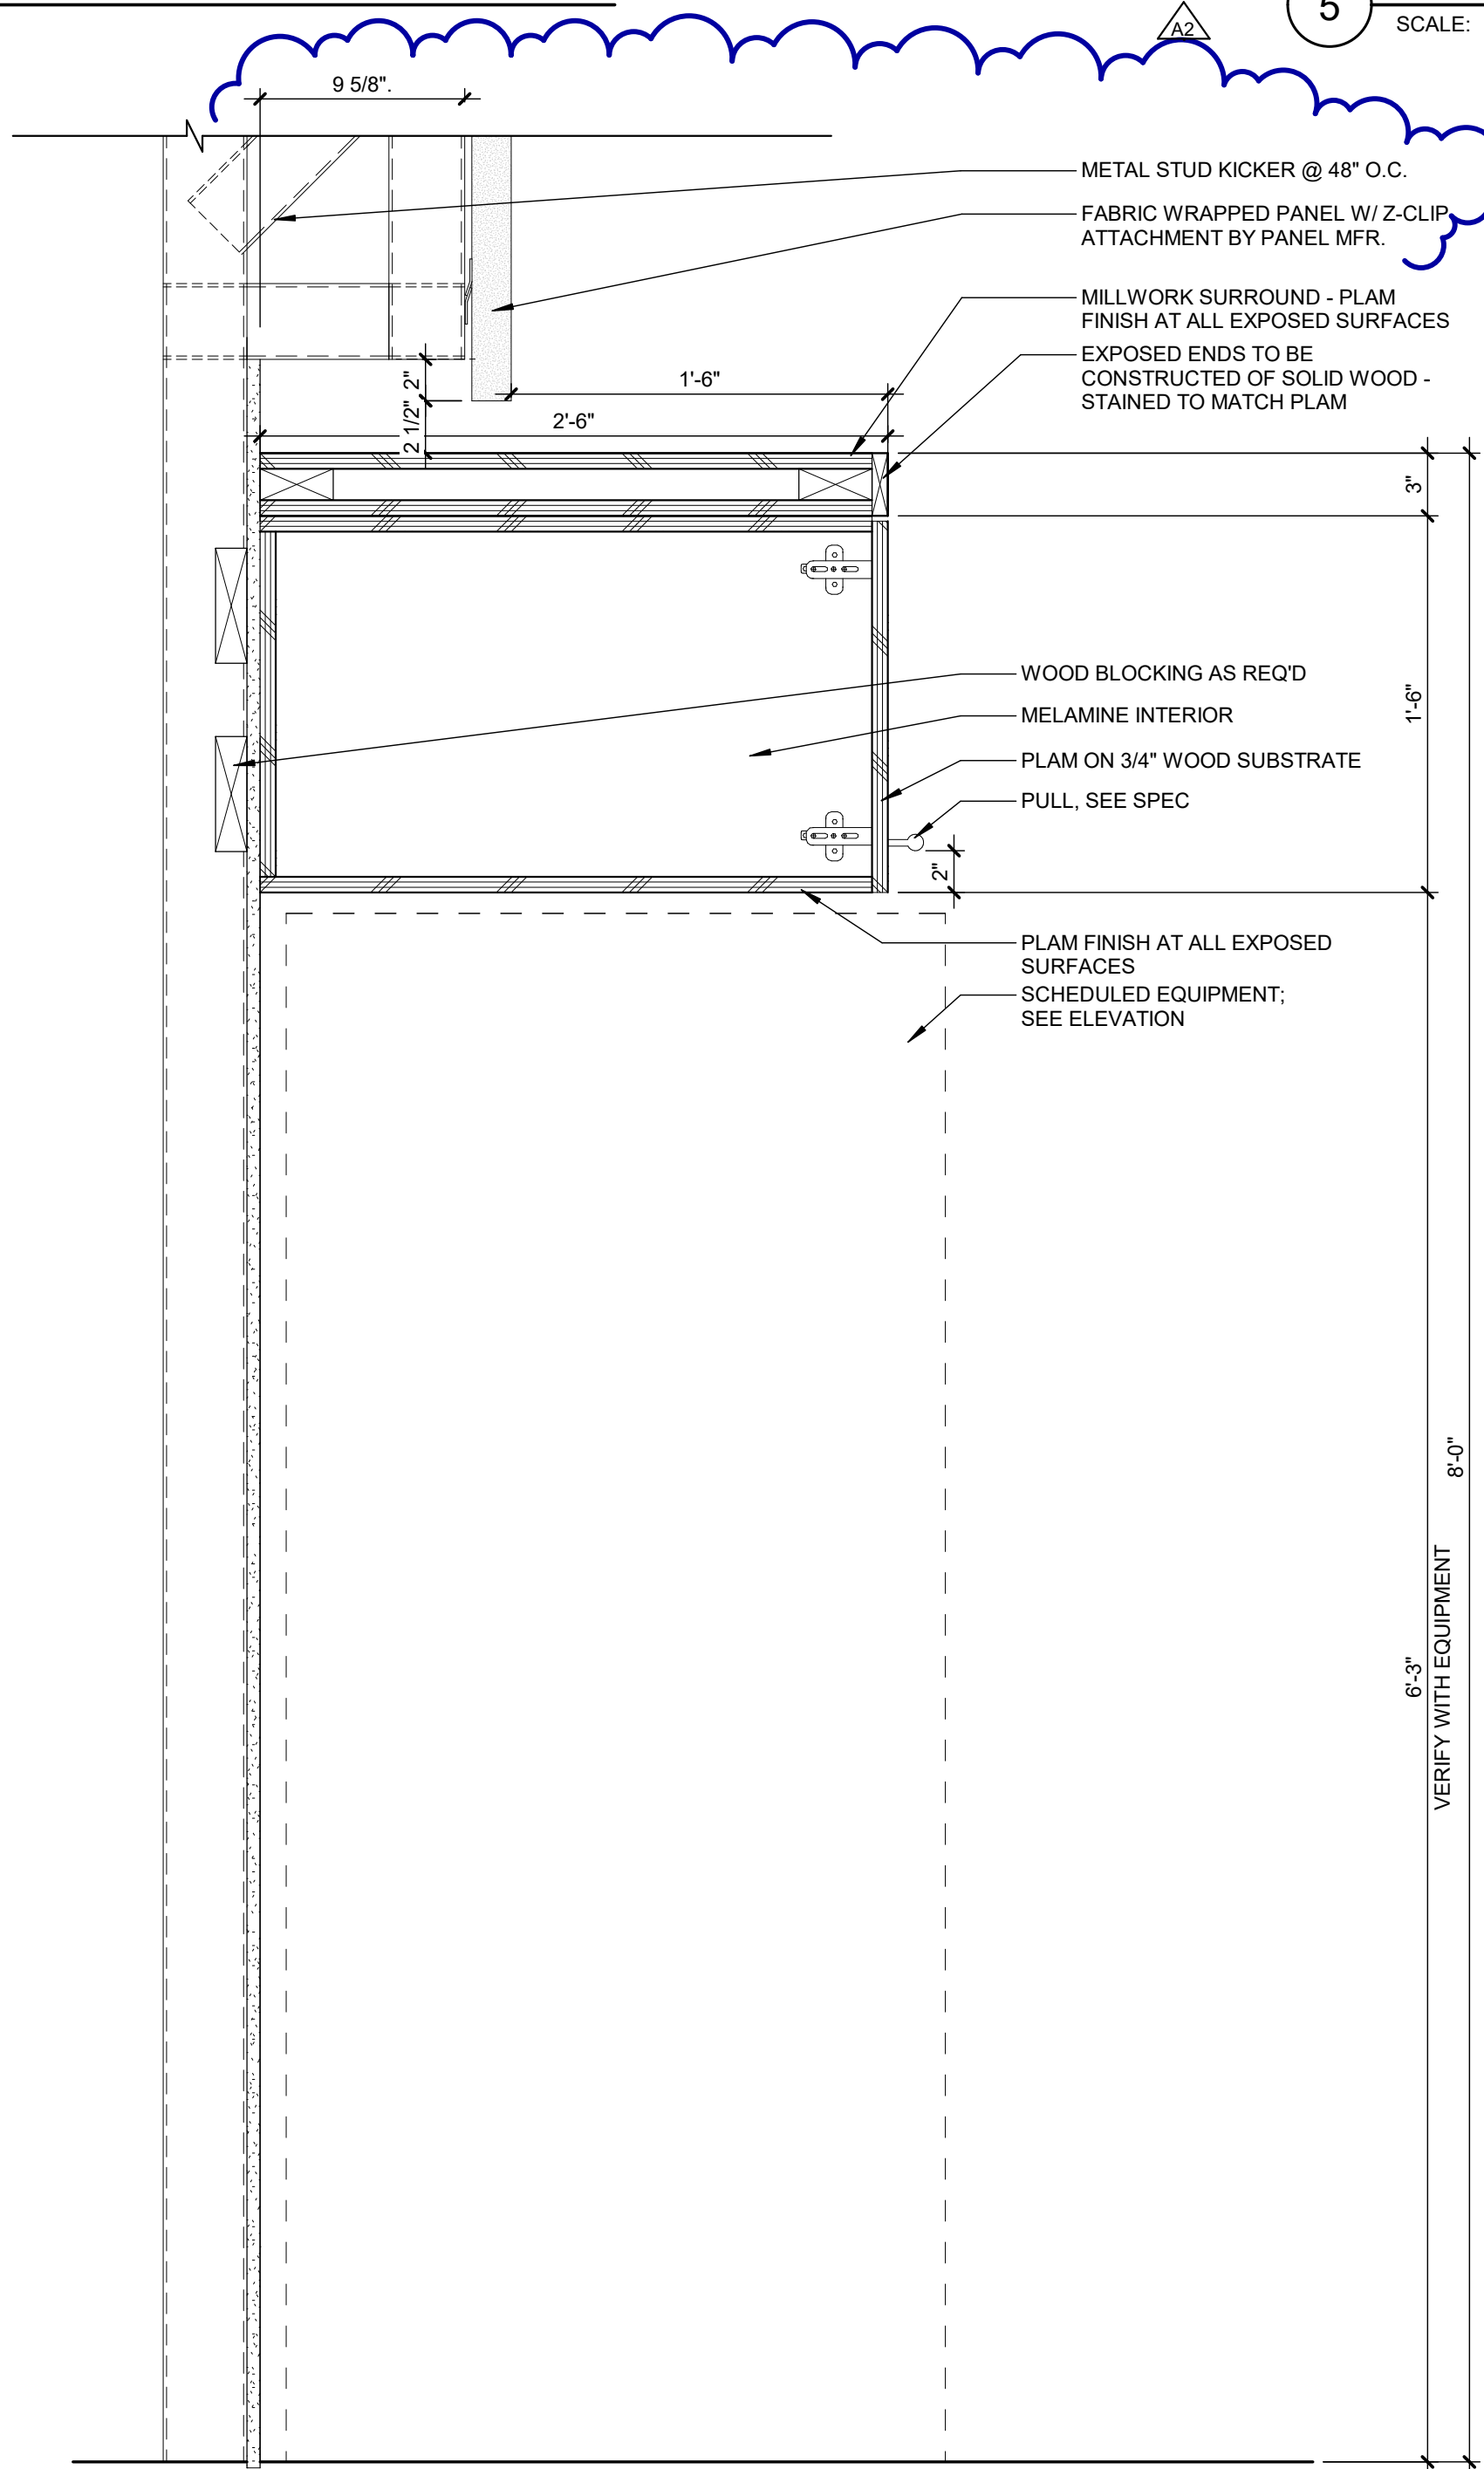

REFRIGERATOR UPPER CABINET

CASEWORK SECTION DETAIL


SCALE: 1 1/2" = 1'-0"

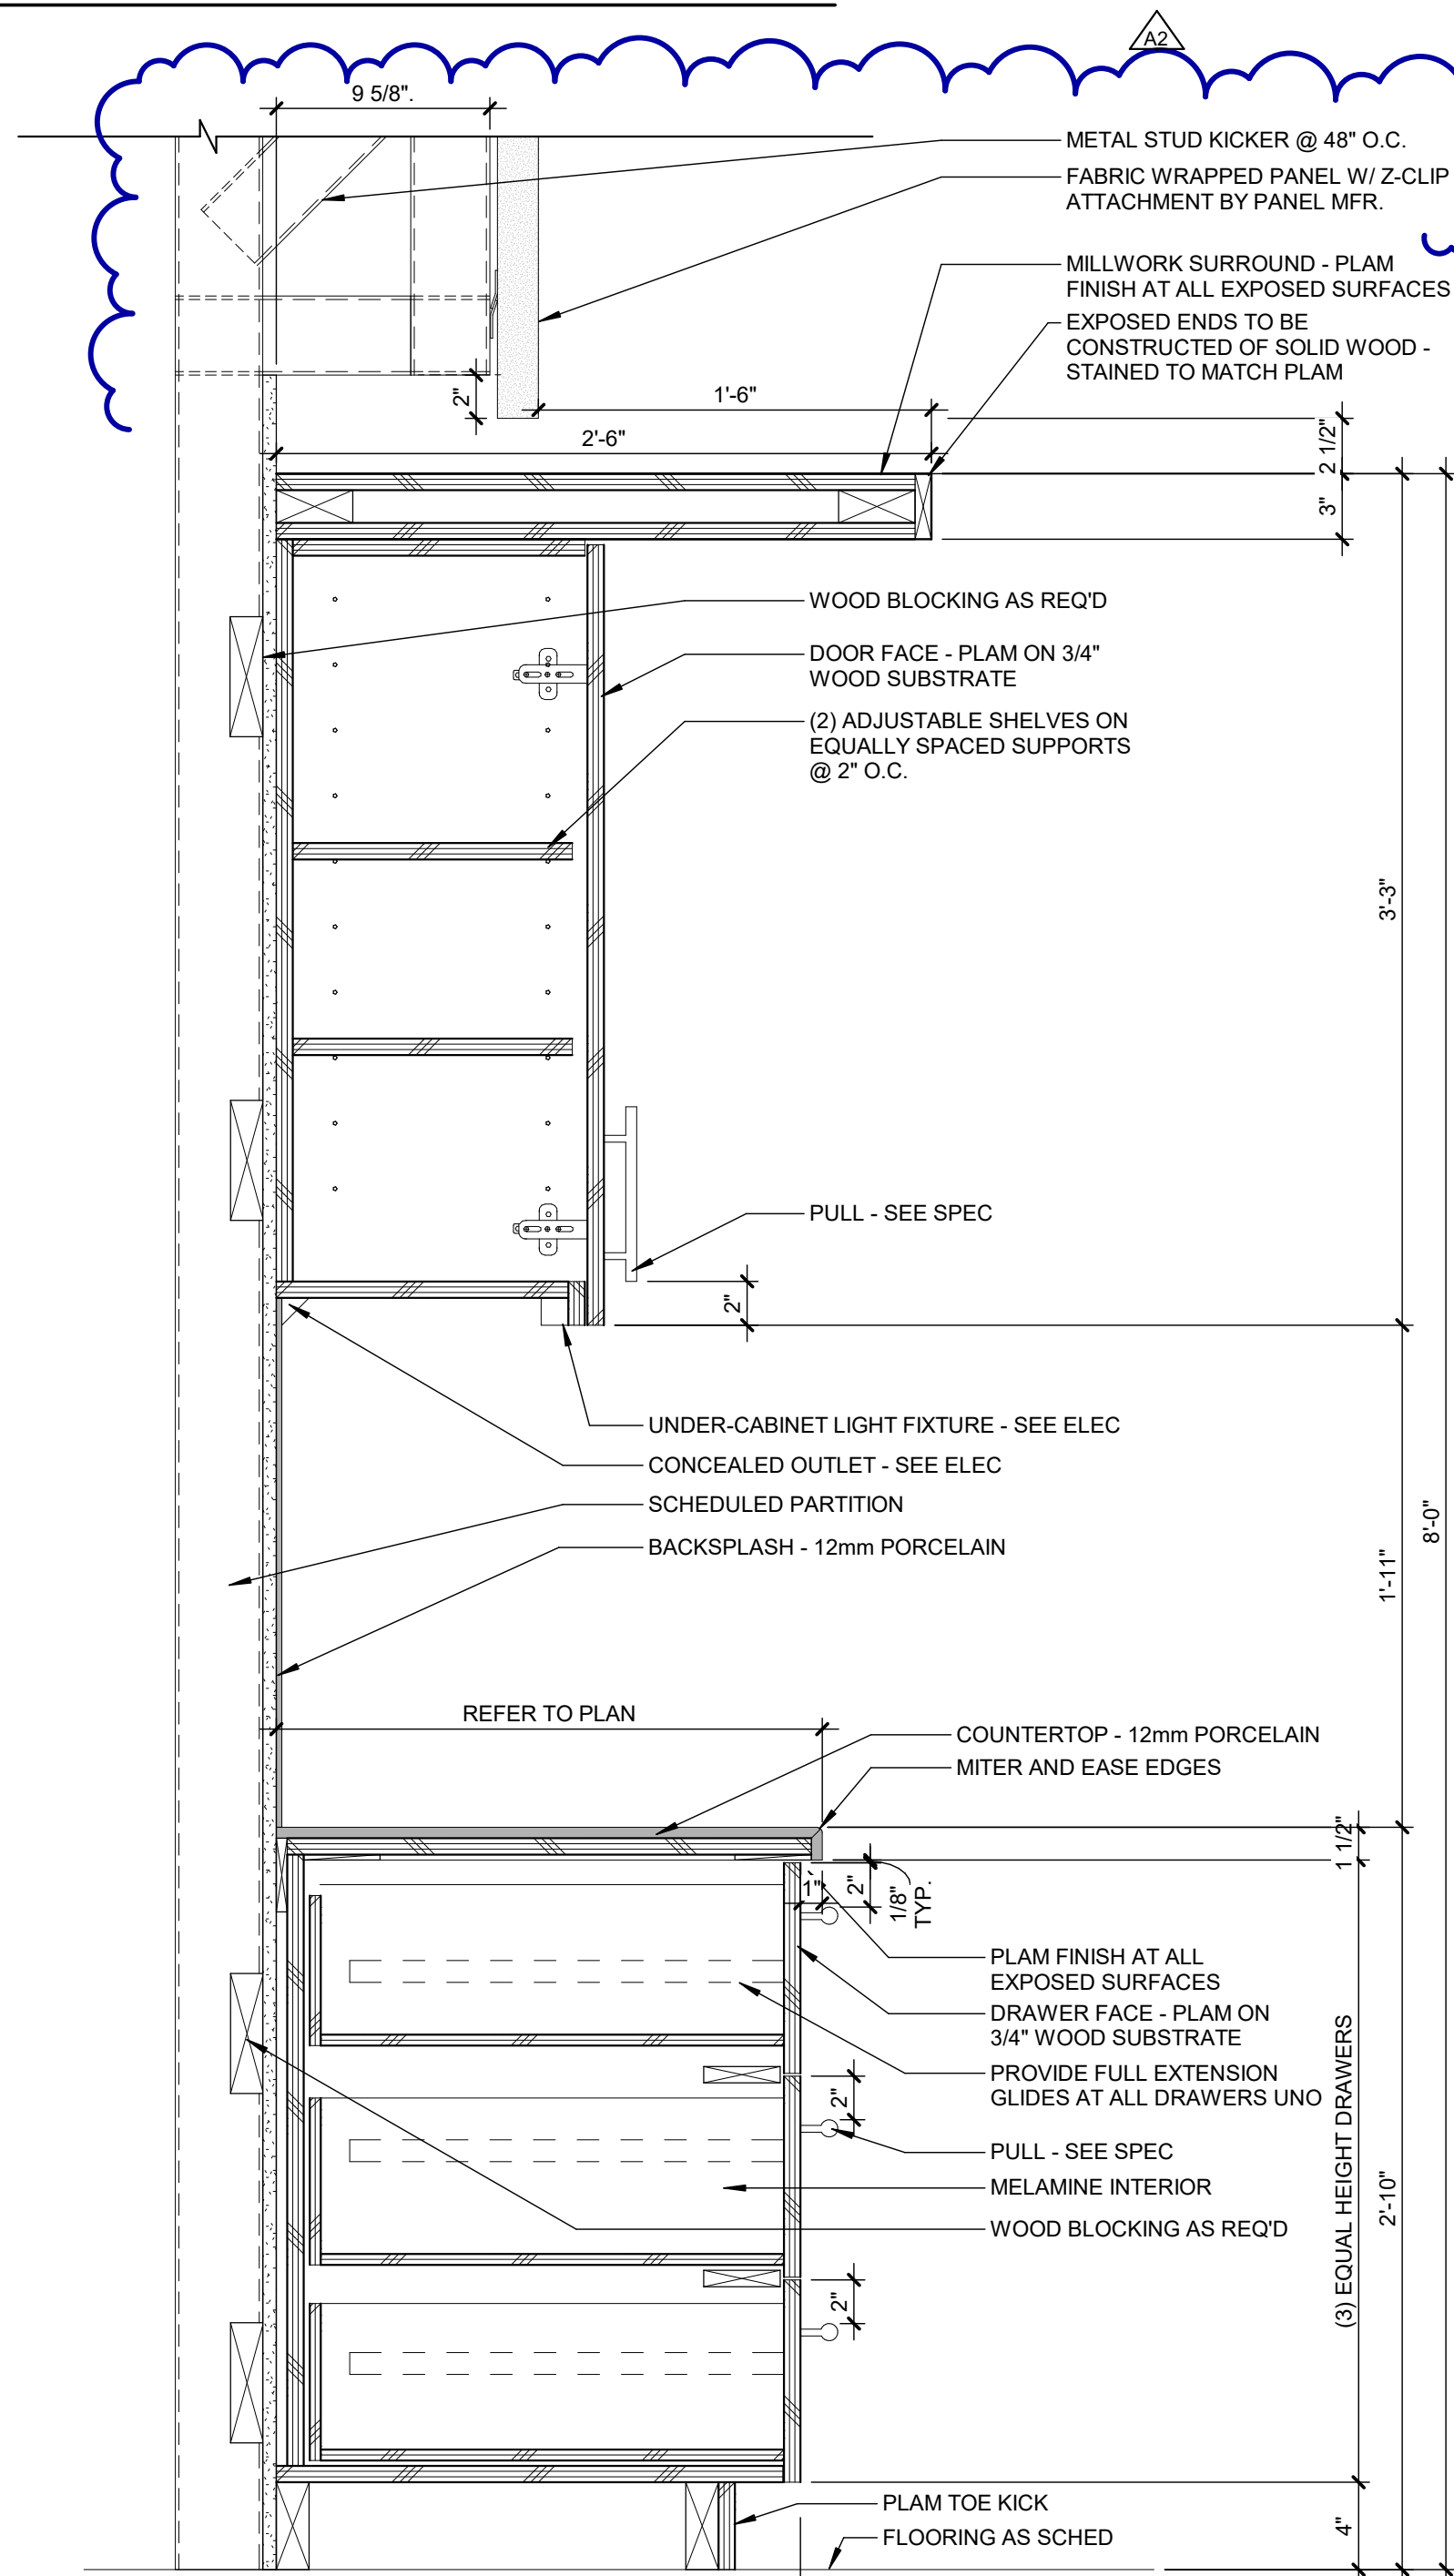

DRAWER BASE AND UPPER

CASEWORK SECTION DETAIL

SCALE: 1 1/2" = 1'-0"

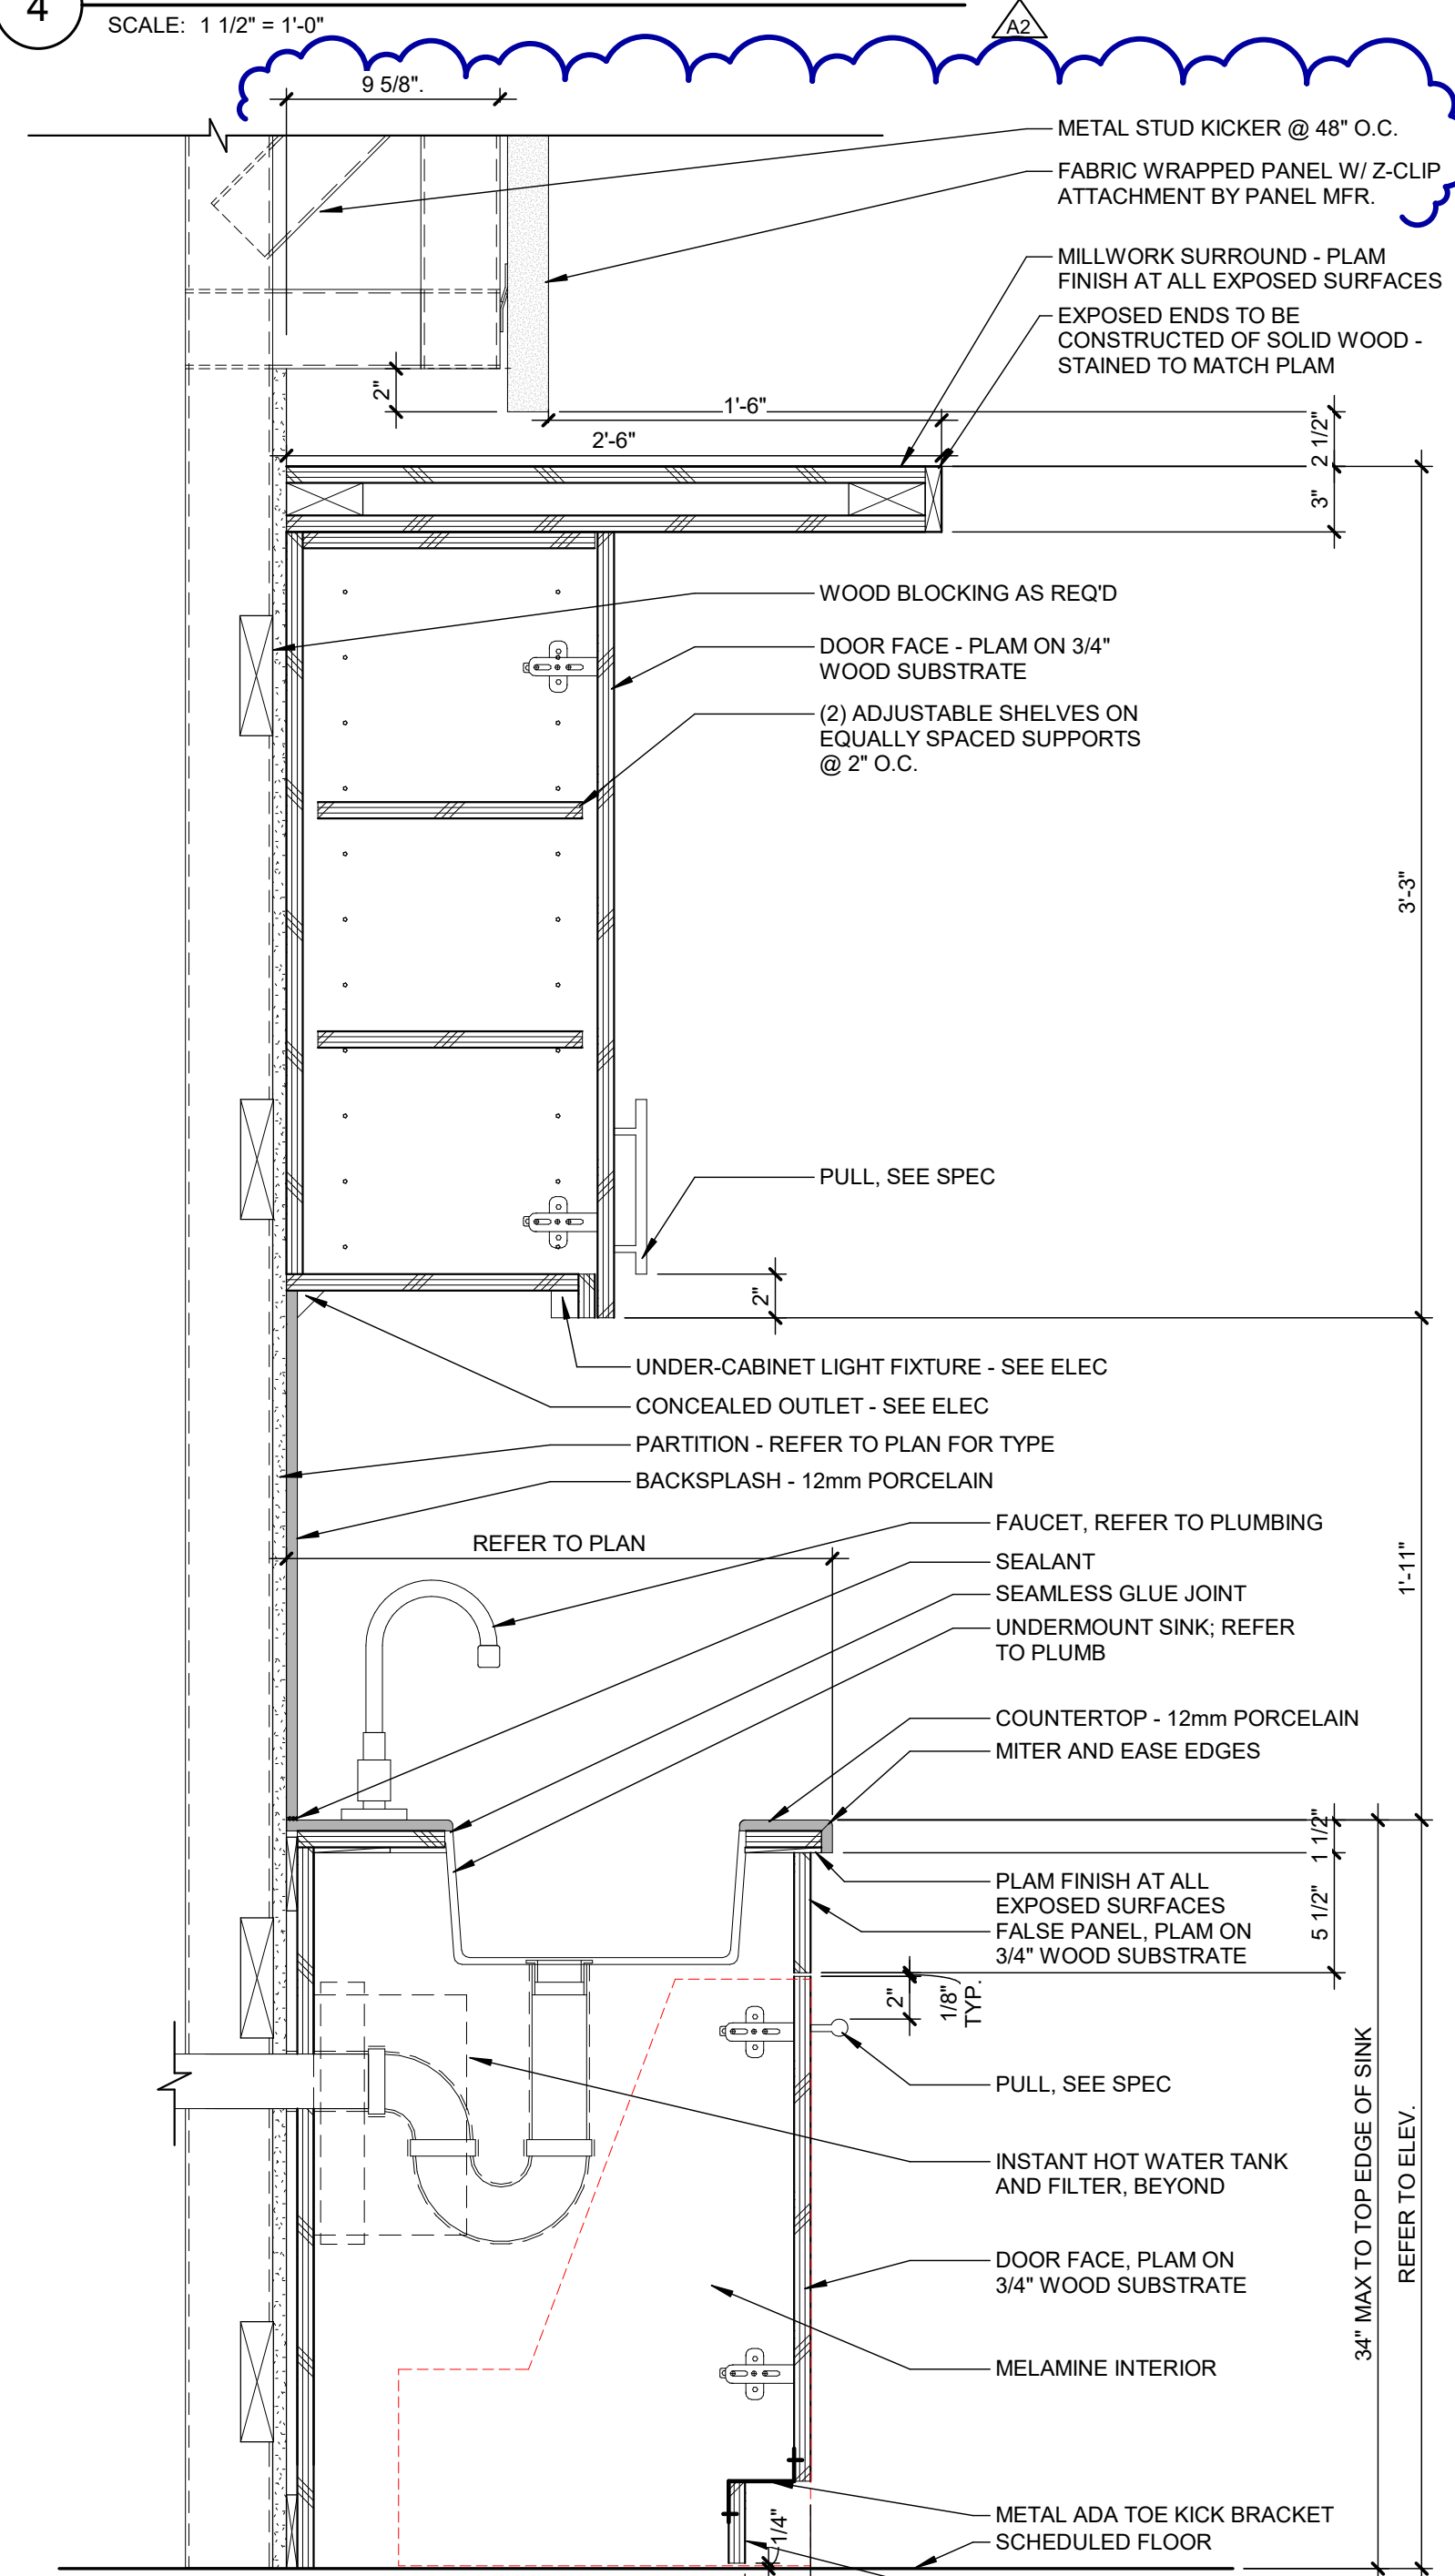

ADA SINK CABINET BASE AND UPPER

CASEWORK SECTION DETAIL

SCALE: 1 1/2" = 1'-0"

Van Buren Charter Township

Van Buren Township, MI

The Lakeside Park

REVISIONS		
10/27/2026	A2	ADDENDUM NO. 2

10/12/2026	BIDS & PERMIT
09/21/2026	CD PEER REVIEW
08/09/2026	CD TEAM REVIEW
08/10/2026	CD 50% PROGRESS
08/22/2026	DD OWNER REVIEW
06/15/2026	DD PEER REVIEW
06/08/2026	DD 90 % PROGRESS
05/18/2026	DD 50 % PROGRESS
02/23/2026	SD OWNER REVIEW
02/13/2026	SD PEER REVIEW
02/09/2026	SD PROGRESS REVIEW

Drawn By IOLKHOVESKA
Designer IELHENNAWY
Reviewer WLRAPSON
Manager CKRETOVIC


Hard copy is intended to be 24"x36" when plotted. Scale(s) indicated and graphic quality may not be accurate for any other size.

PROJECT NO.
2500281


SHEET NO.

A525


©Copyright 2026
All Rights Reserved

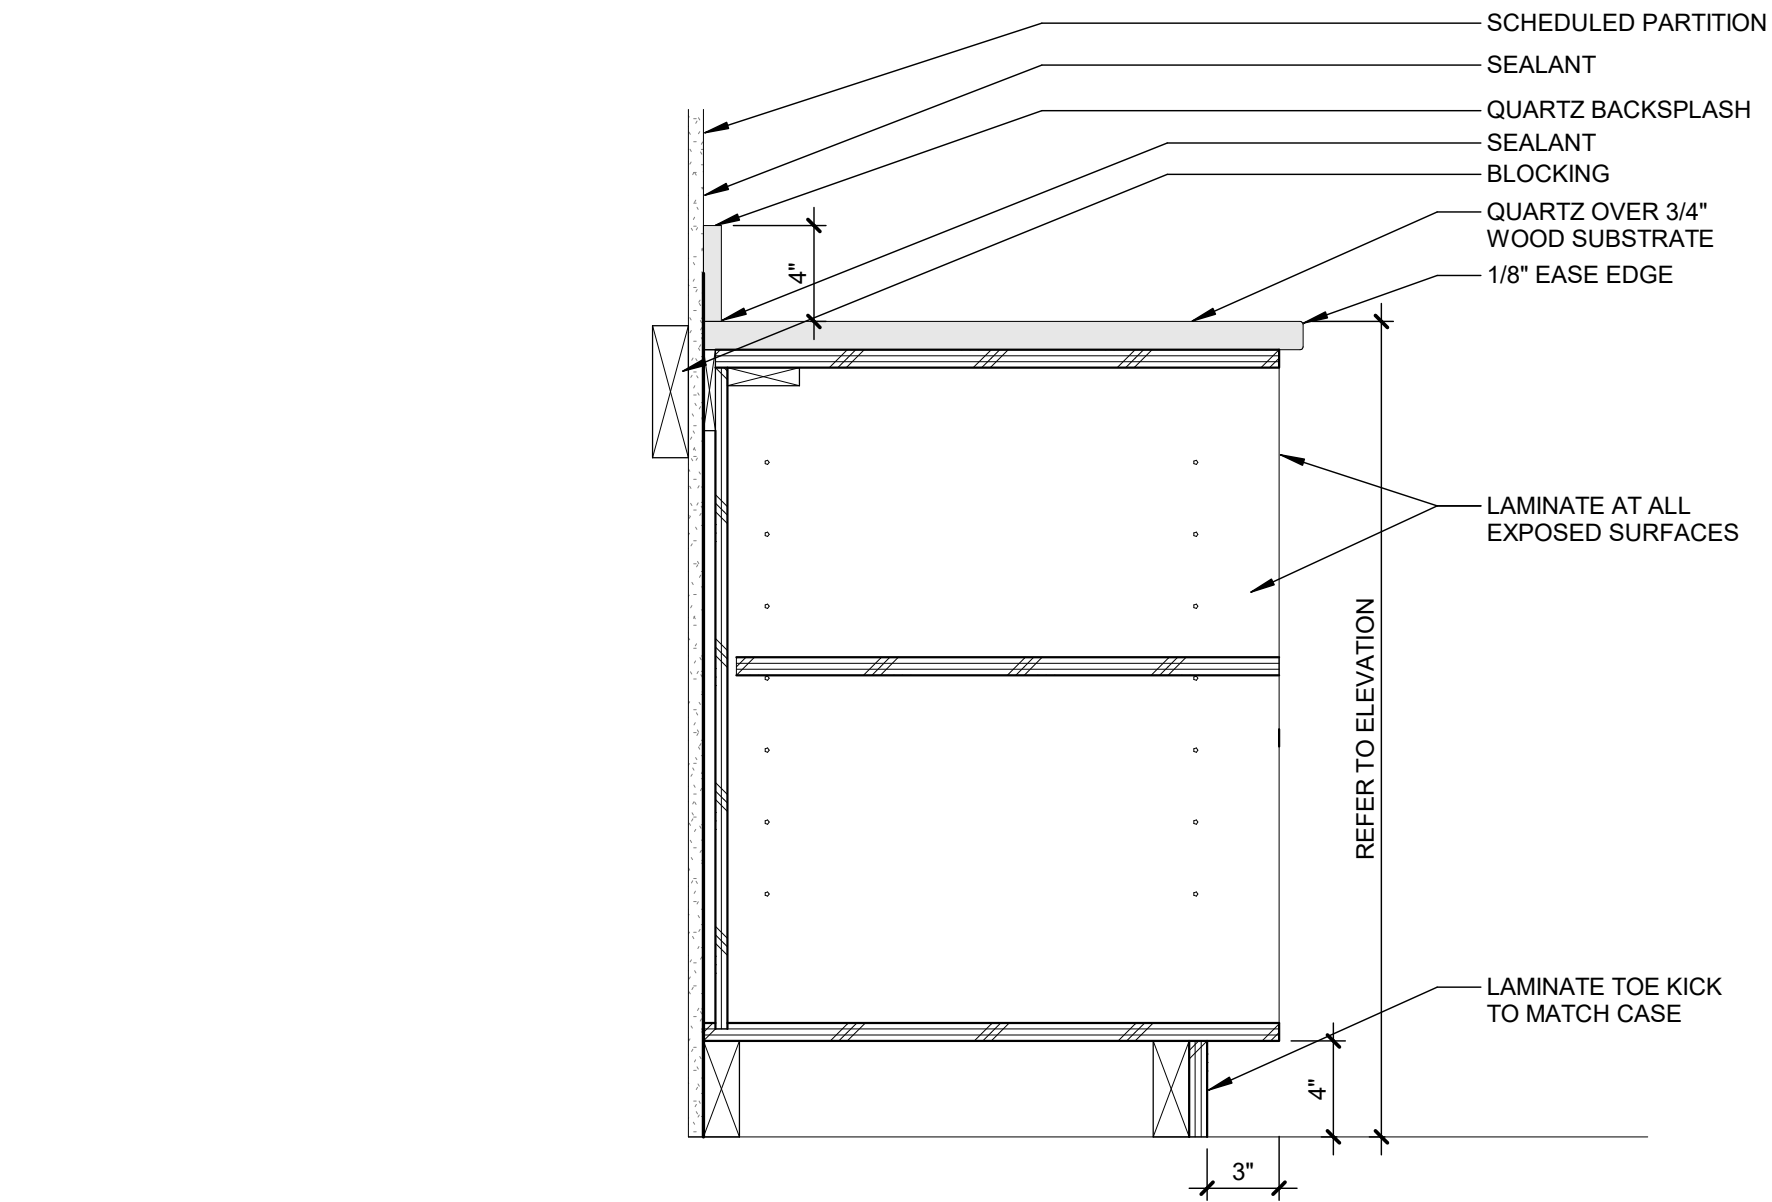


4 DRESSING CASEWORK COUNTER STORAGE
SCALE: 1 1/2" = 1'-0"

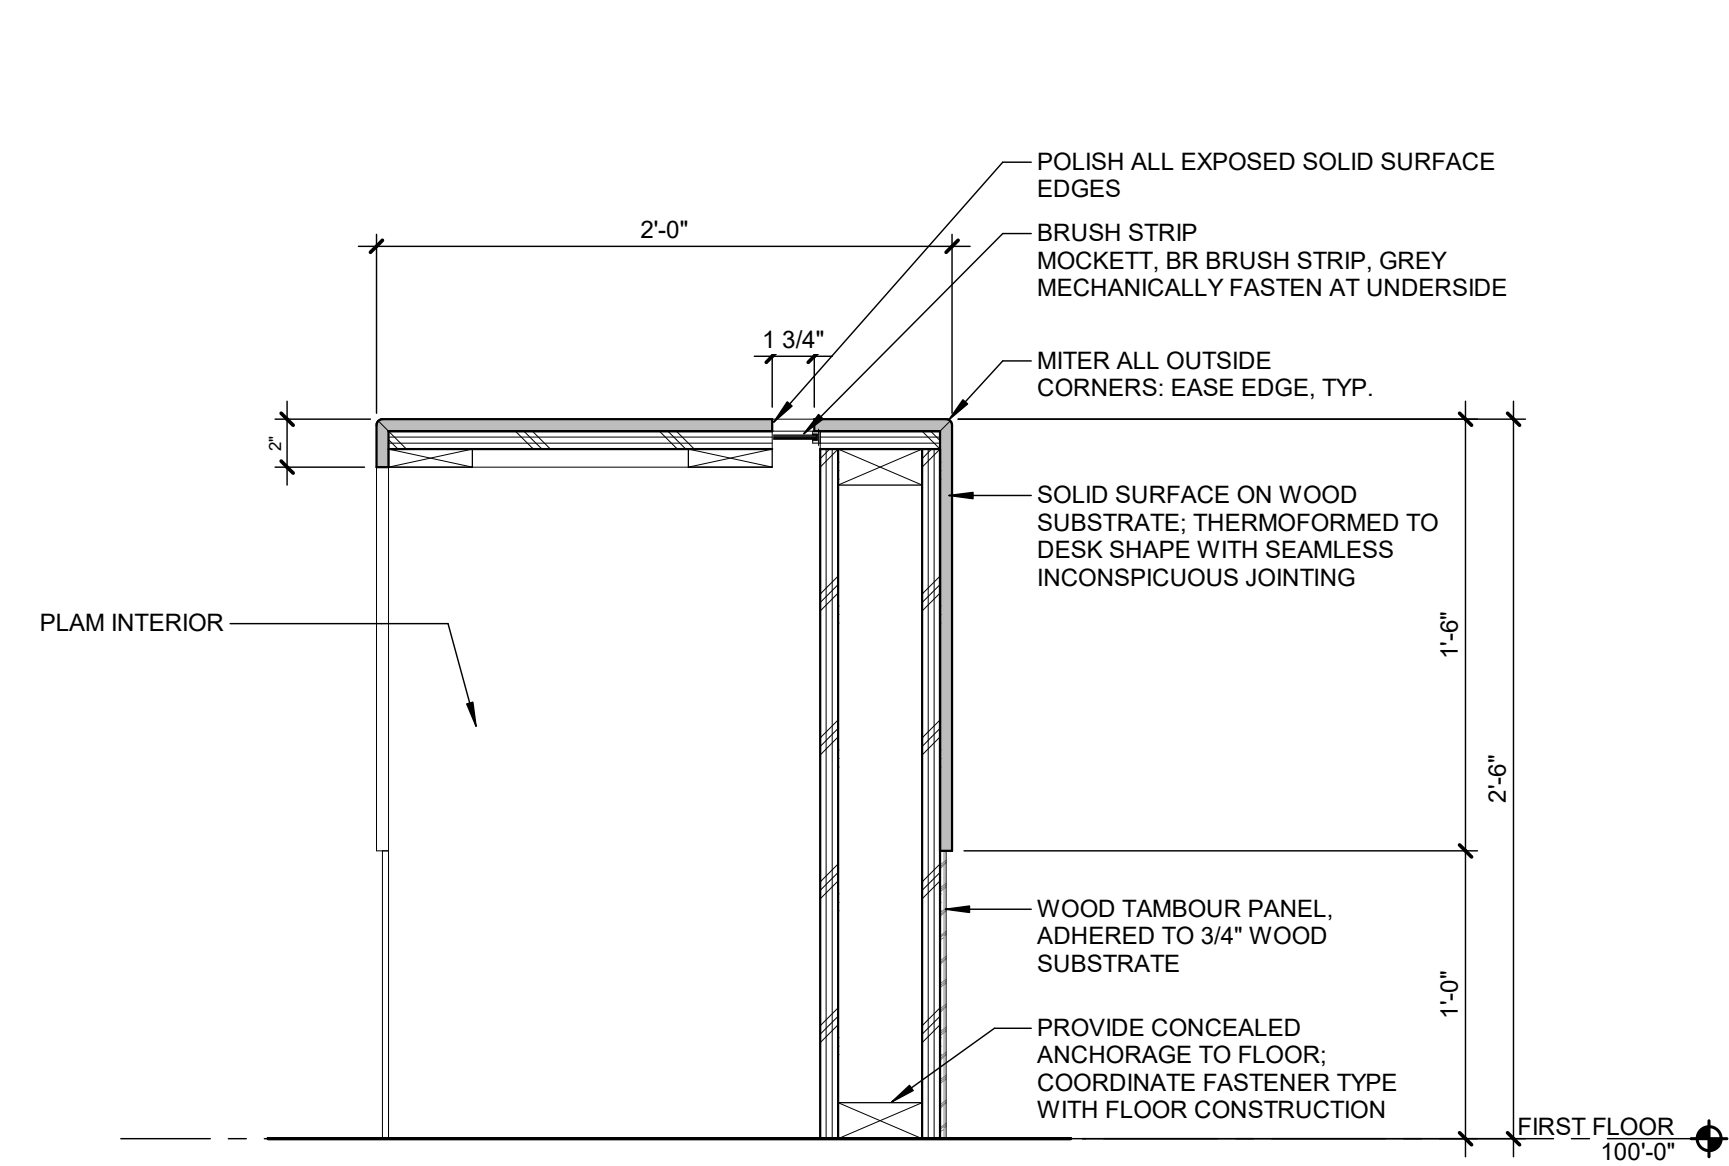

3 RECEPTION DESK
SCALE: 1 1/2" = 1'-0"

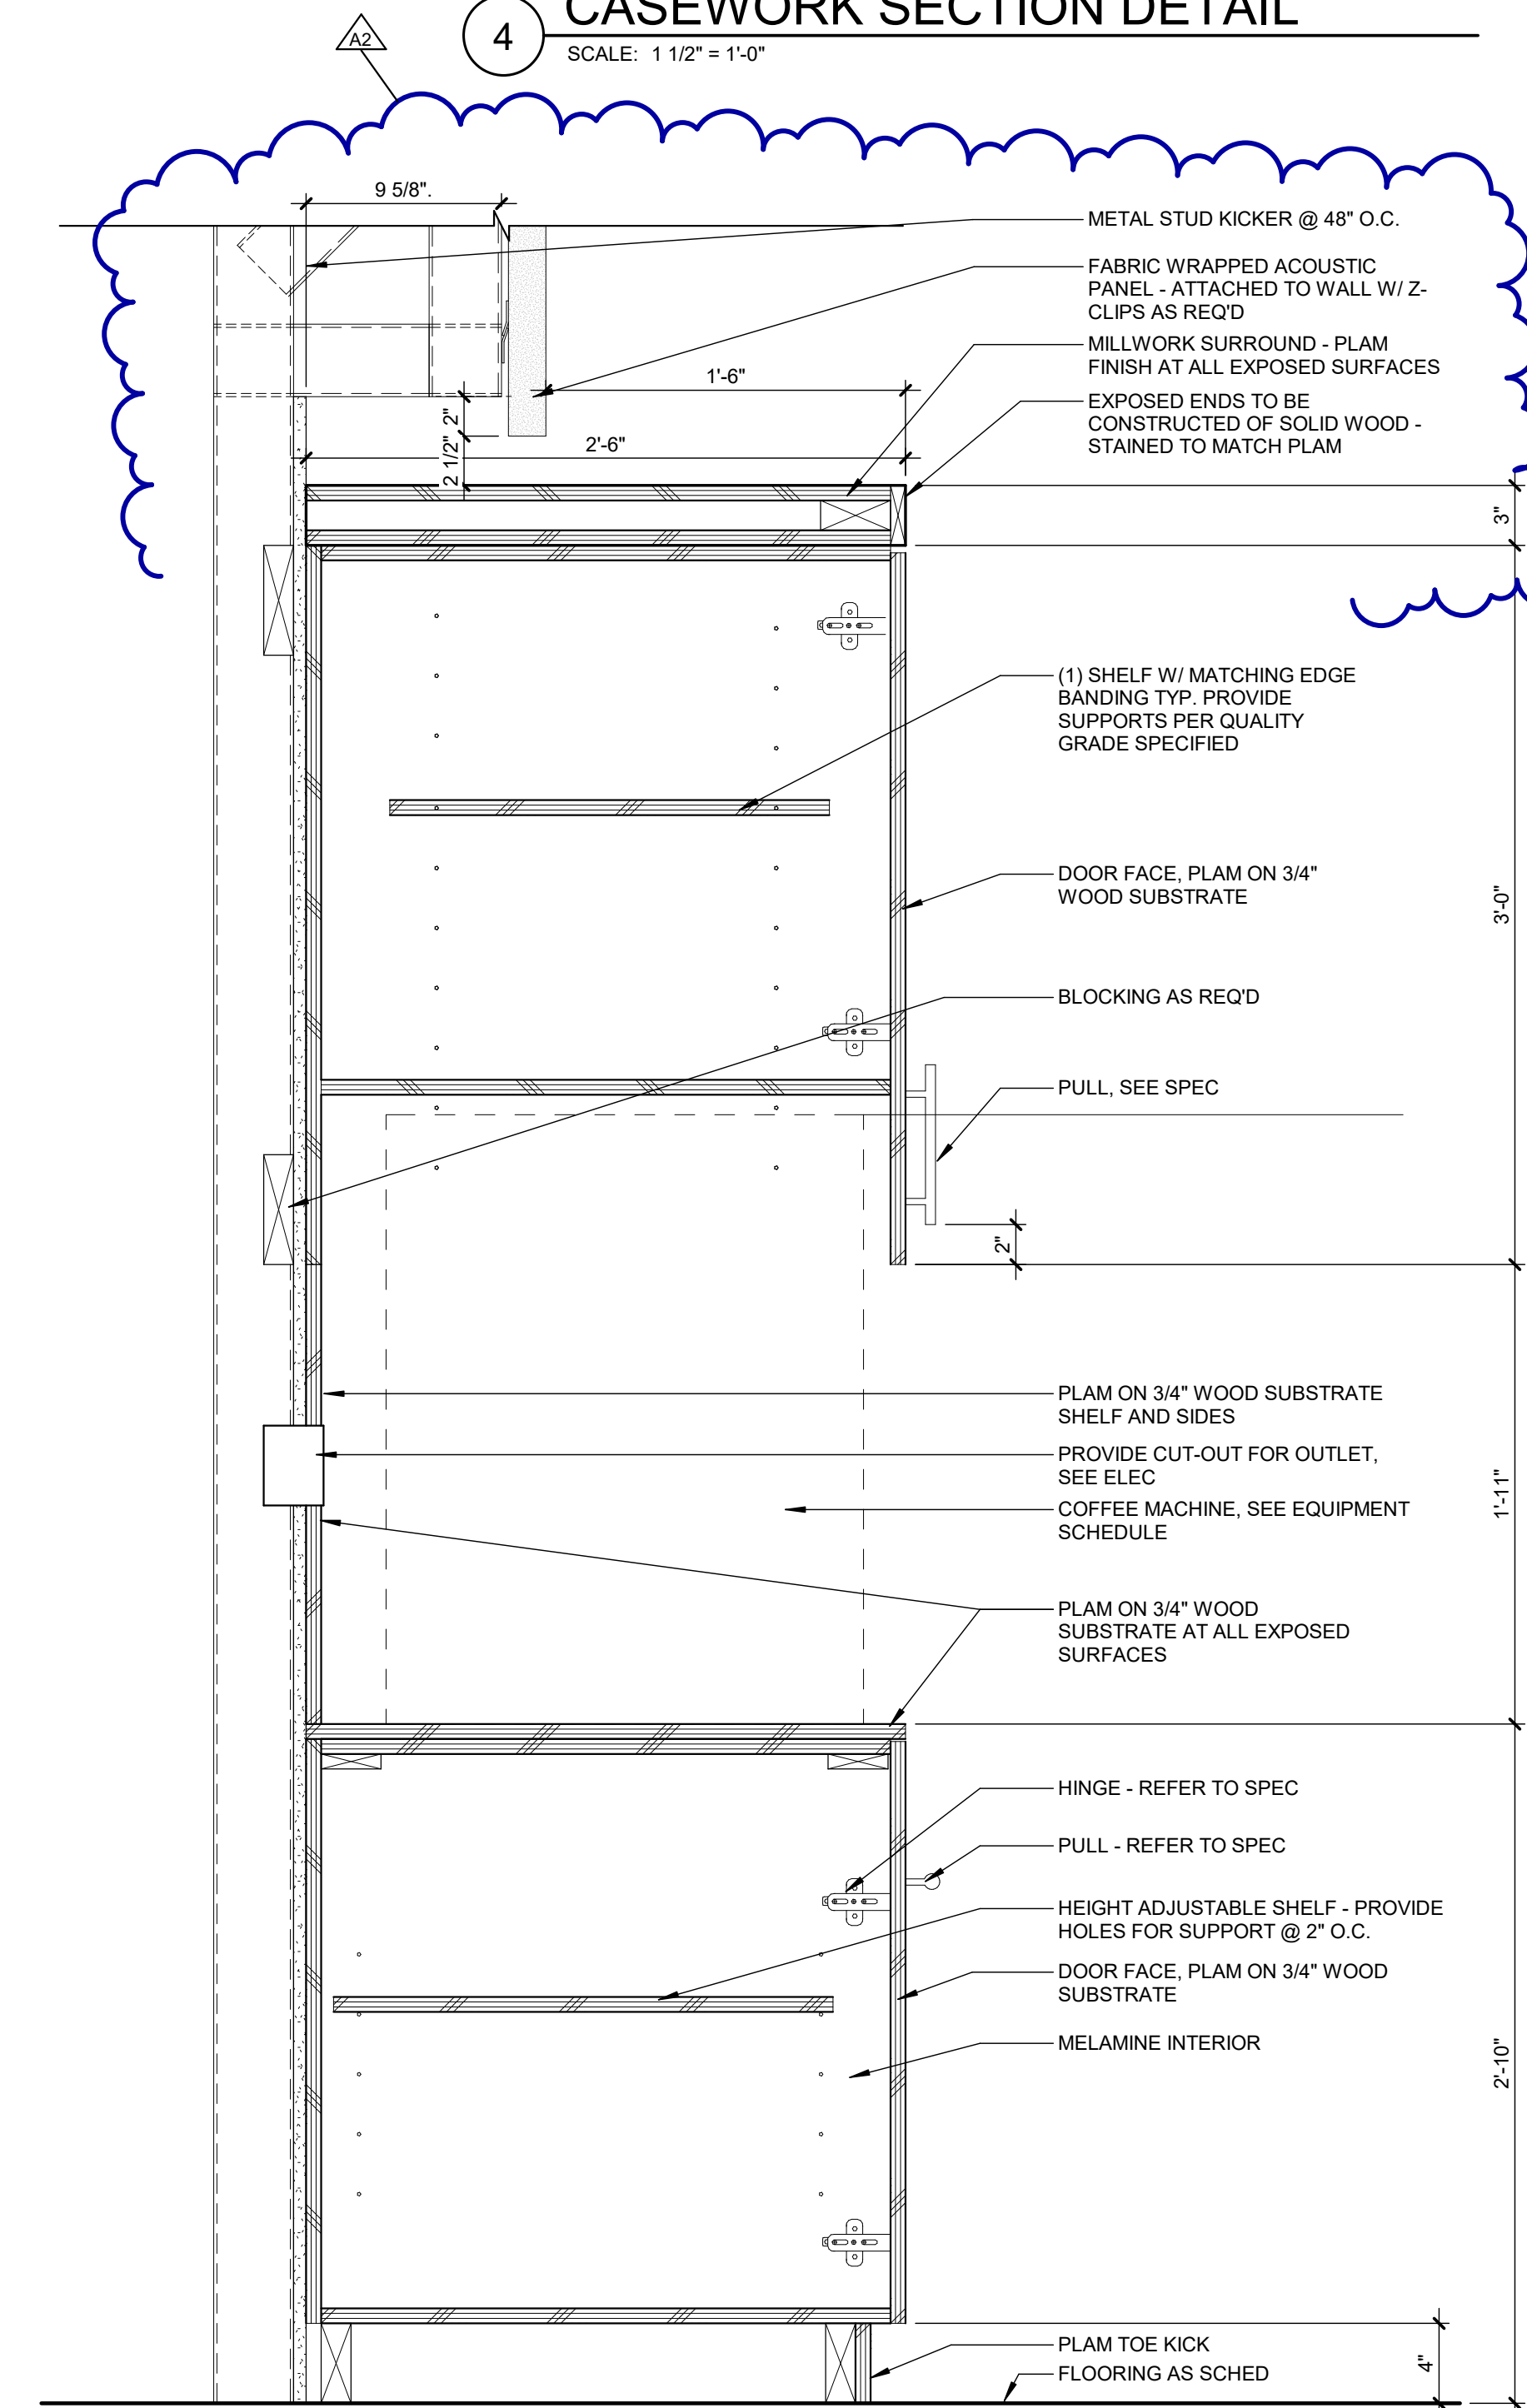

2 TALL COFFEE MAKER CABINET
SCALE: 1 1/2" = 1'-0"

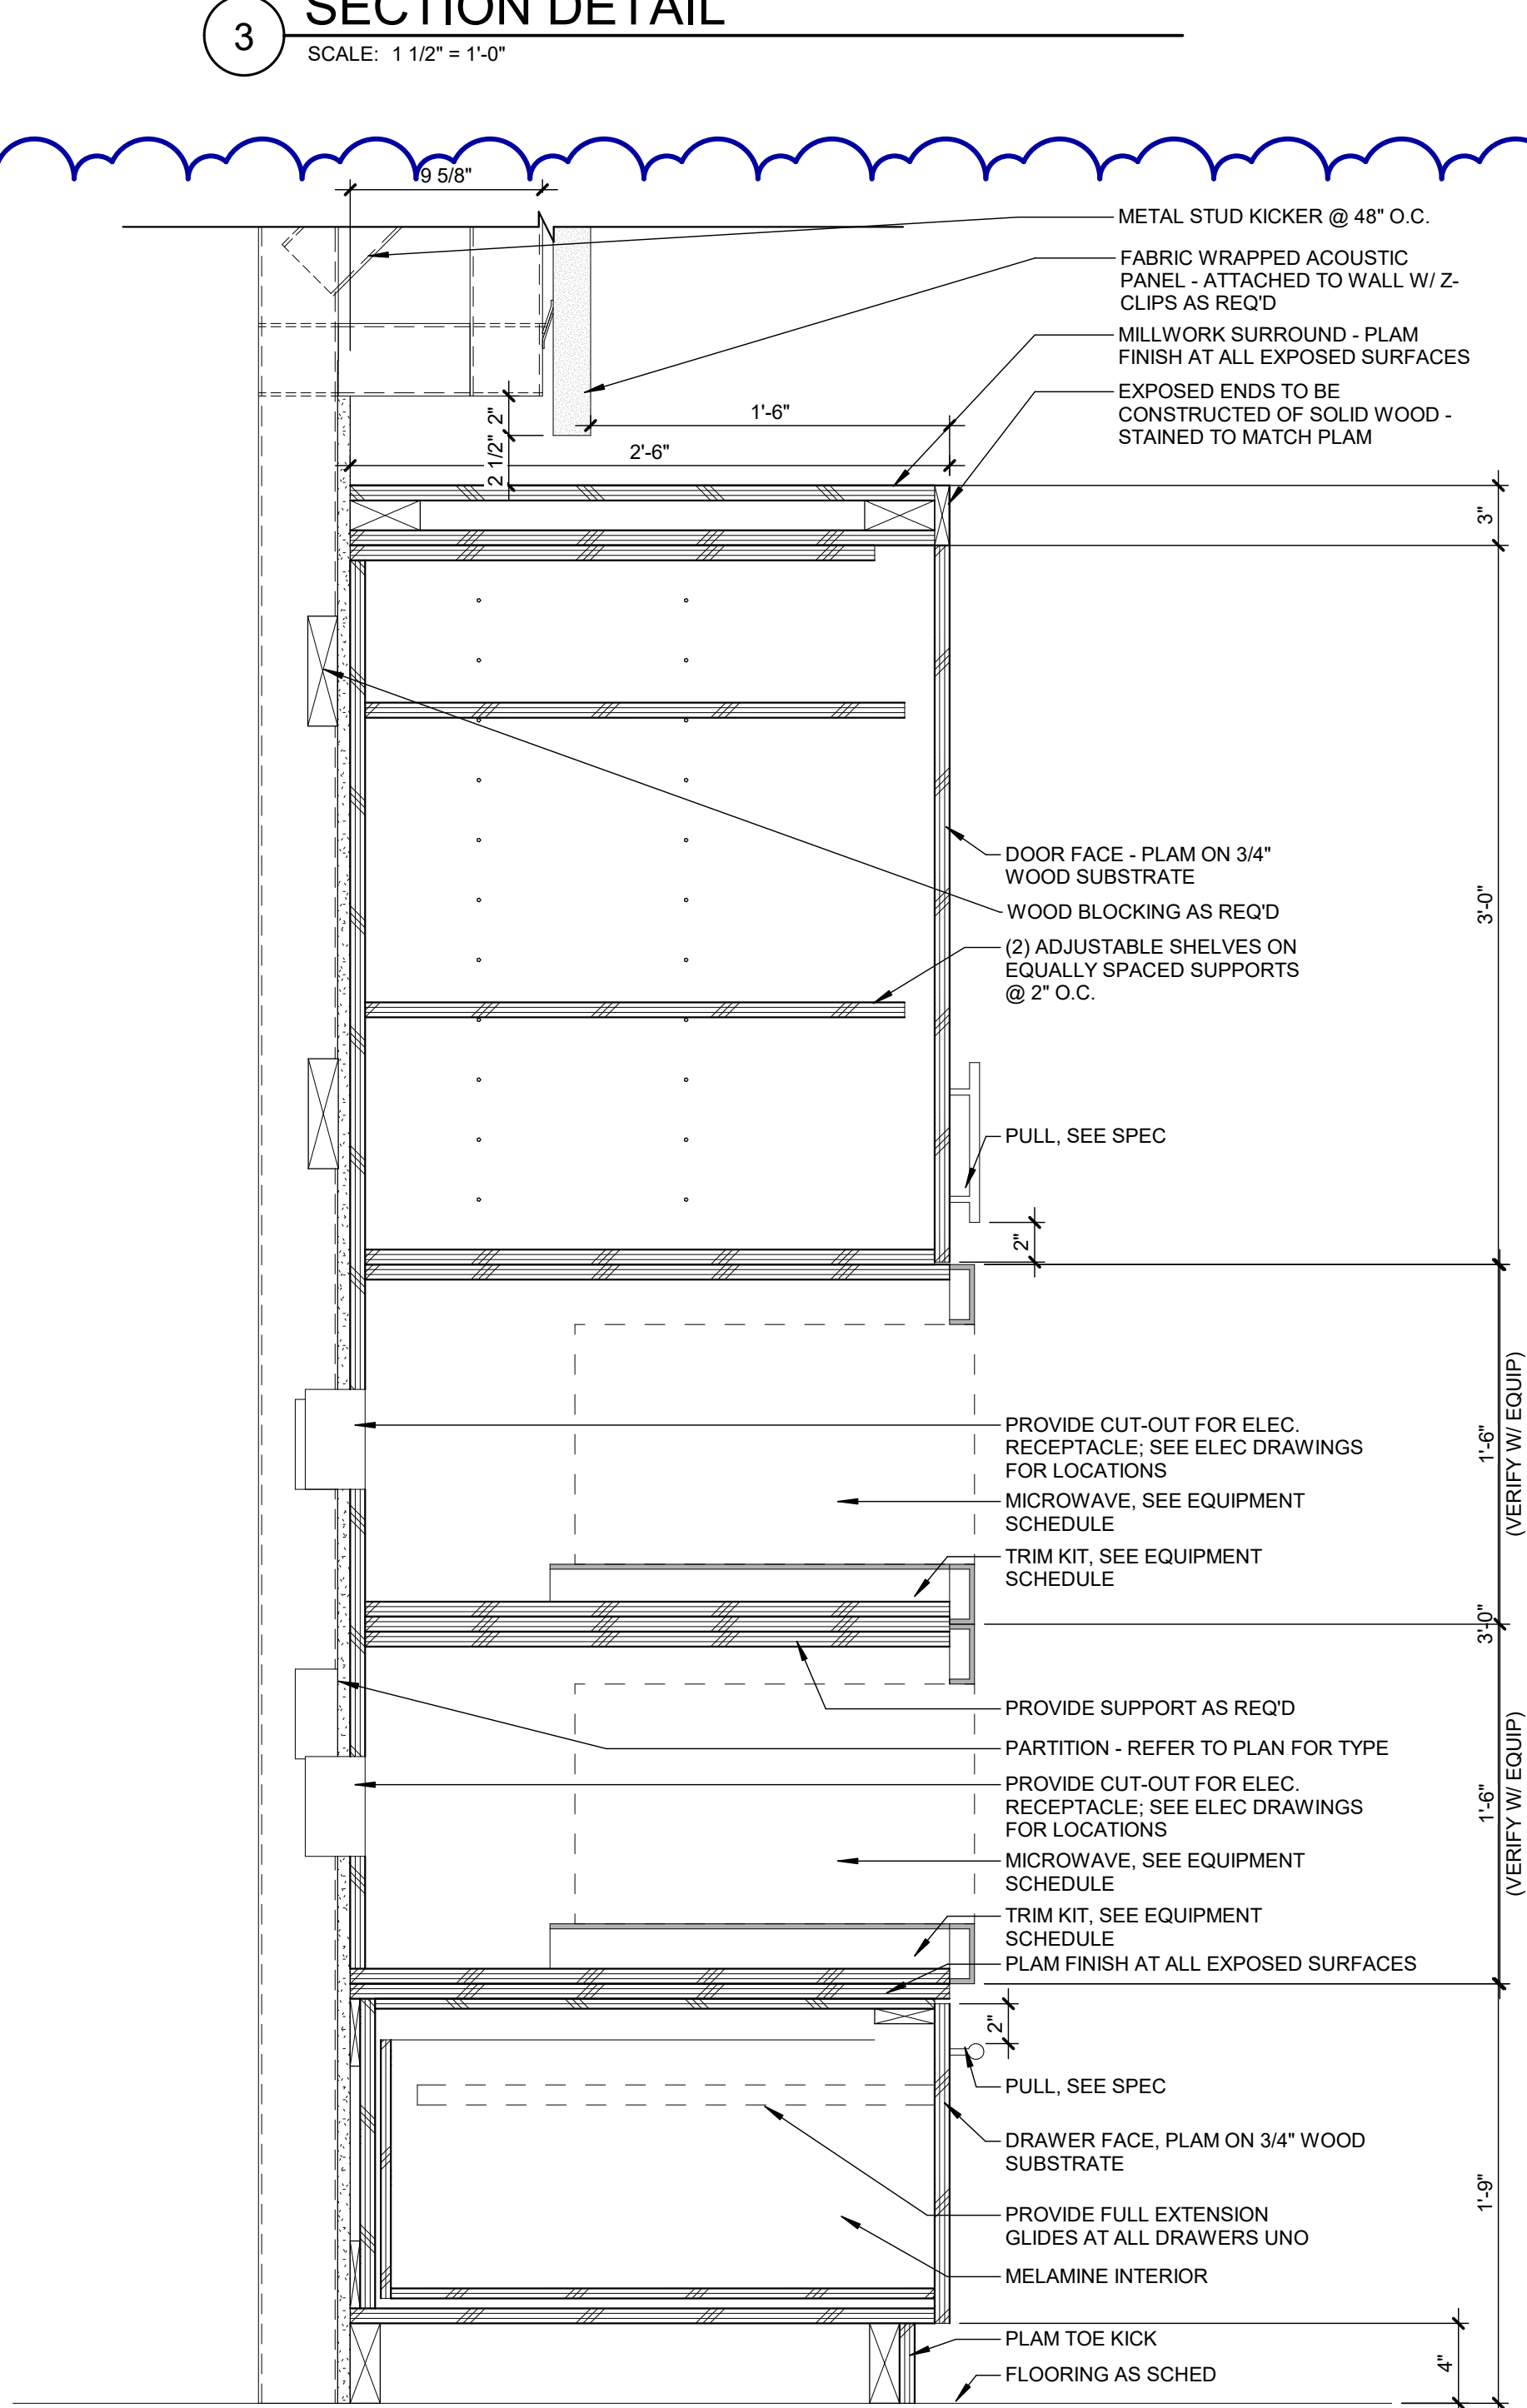

1 TALL MICROWAVE CABINET
SCALE: 1 1/2" = 1'-0"

REVISIONS		
10/27/2026	A2	ADDENDUM NO. 2

10/12/2026	BIDS & PERMIT
09/21/2026	CD PEER REVIEW
09/09/2026	CD TEAM REVIEW
08/10/2026	CD 50% PROGRESS
08/22/2026	DD OWNER REVIEW
06/15/2026	DD PEER REVIEW
06/08/2026	DD 90 % PROGRESS
05/18/2026	DD 50 % PROGRESS
02/23/2026	SD OWNER REVIEW
02/13/2026	SD PEER REVIEW
02/09/2026	SD PROGRESS REVIEW

Drawn By	IOLKHOVESKA
Designer	IELHENNAWY
Reviewer	WLAPSON
Manager	CKRETOVIC


Hard copy is intended to be 24"x36" when plotted. Scale(s) indicated and graphic quality may not be accurate for any other size.


PROJECT NO.
2500281
SHEET NO.


PLOT INFO: 10/27/2026 10:34:15 AM Autodesk Docs/2500281 - Van Buren Twp Lake House/2026_S_2500281.rvt


CONCRETE PIER SCHEDULE					
MARK	SIZE	VERTICAL REINFORCEMENT	TIES	TYPE	REMARKS
	W x L				
P1	22" x 22"	(8) #6	(3)#3@2" TOP #3@10" OC	A	
P2	26" x 26"	(12) #6	(3)#3@2" TOP #3@10" OC	B	
P3	32" x 24"	(12) #6	(3)#3@2" TOP #3@10" OC	C	SEE PLAN FOR OFFSET ORIENTATION
P4	32" x 32"	(12) #6	(3)#3@2" TOP #3@10" OC	D	SEE PLAN FOR OFFSET ORIENTATION
P5	24" x 24"	(8) #6	(3)#3@2" TOP #3@10" OC	A	

TYPES:

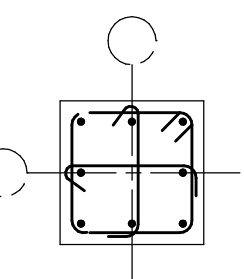
TYPE A

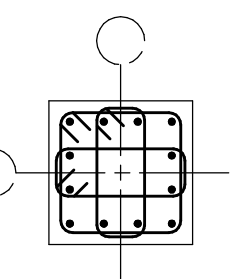
TYPE B

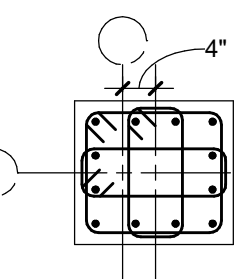
TYPE C

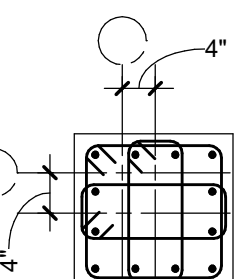

TYPE D

BASE PLATE SCHEDULE					
MARK	SIZE (WxL)	THICKNESS	ANCHOR DIA.	ANCHOR EMBED	DETAIL
BP1	16"x16"	3/4"	3/4"	9"	A
BP2	20"x20"	1 1/2"	1 1/2"	24"	B
BP3	11"x11"	3/4"	3/4"	9"	C


FOOTING SCHEDULE				
MARK	LENGTH	WIDTH	DEPTH	REINFORCEMENT
F4x3	3' - 4"	4' - 0"	1' - 0"	(5)#5 EACH WAY
F4	4' - 0"	4' - 0"	1' - 0"	(5)#5 EACH WAY
F5	5' - 0"	5' - 0"	1' - 0"	(6)#5 EACH WAY
F6	6' - 0"	6' - 0"	1' - 0"	(7)#5 EACH WAY
SKYRING	11' - 0"	16' - 10"	2' - 6"	TBD

NOTES


- TOP OF PIER ELEVATION = 99'-0", UNLESS NOTED OTHERWISE.
- TOP OF FOOTING ELEVATION = 97'-0", UNLESS NOTED OTHERWISE.
- TOP OF WALL ELEVATION = 99'-0", UNLESS NOTED OTHERWISE.
- REFER TO CIVIL AND ARCHITECTURAL FOR EXTERIOR SLABS AND STAIRS.

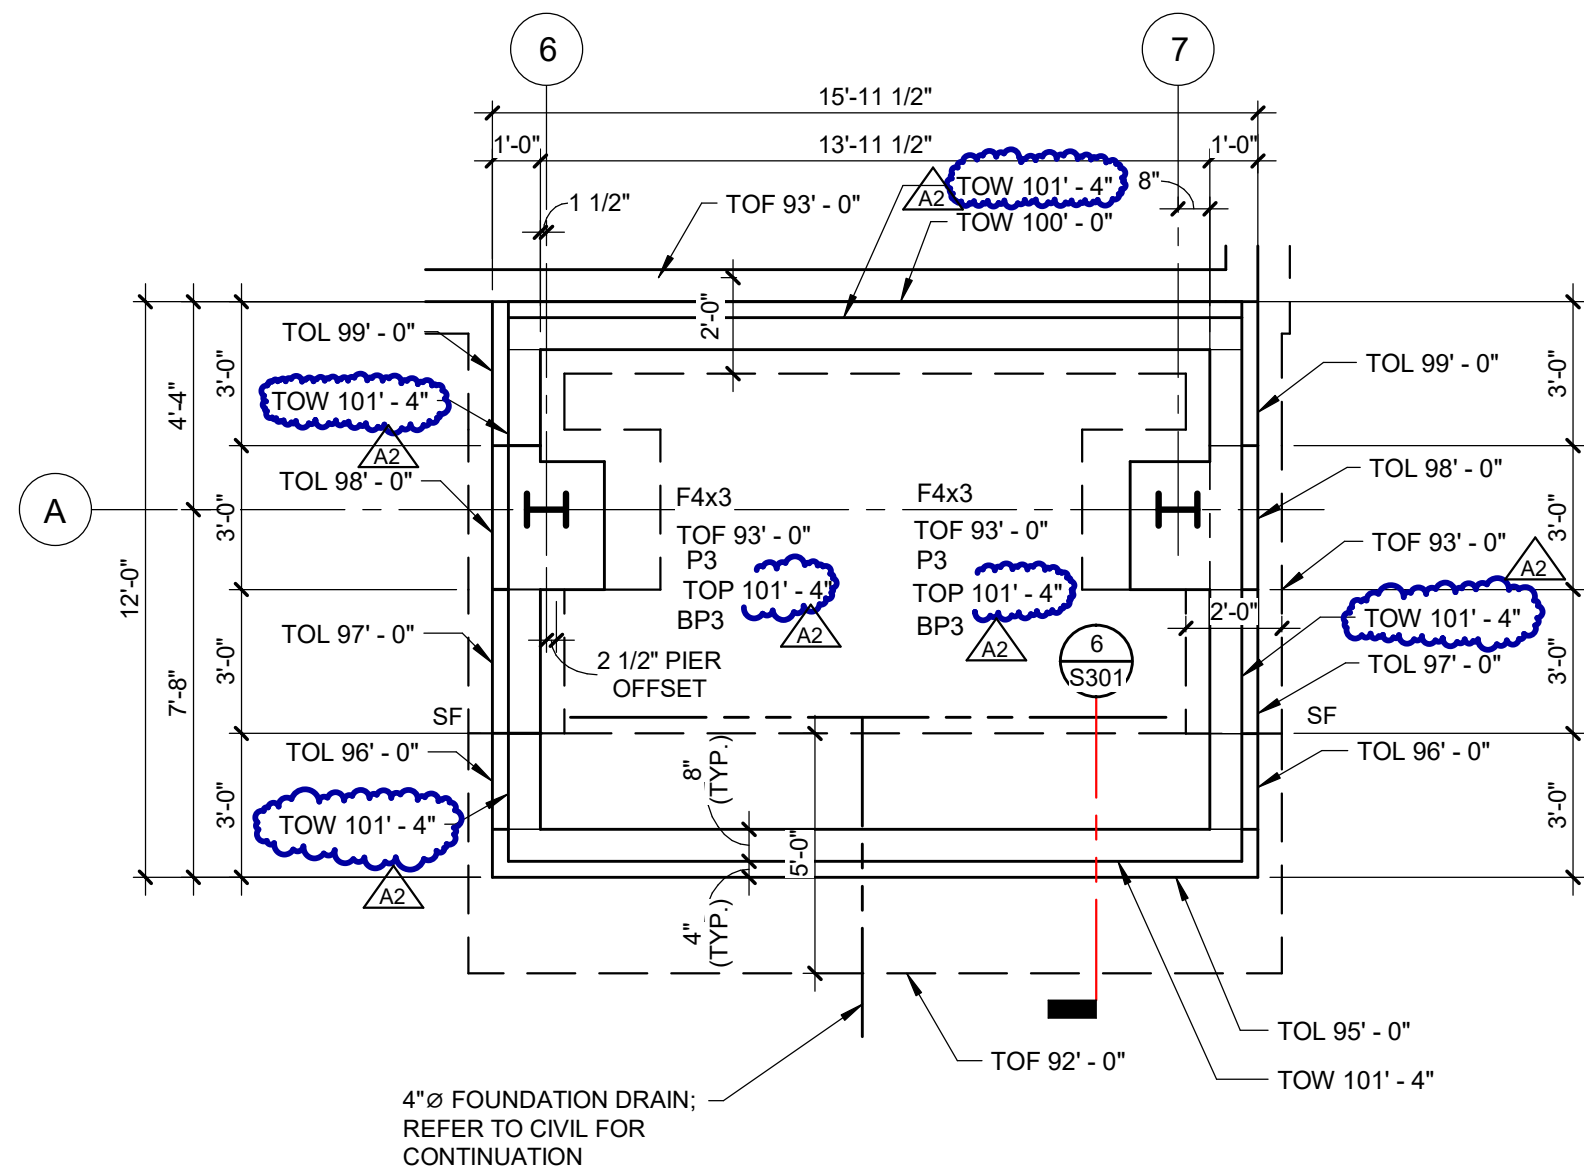

2 ENLARGED EAST FOUNDATION PLAN
SCALE: 1/4" = 1'-0"

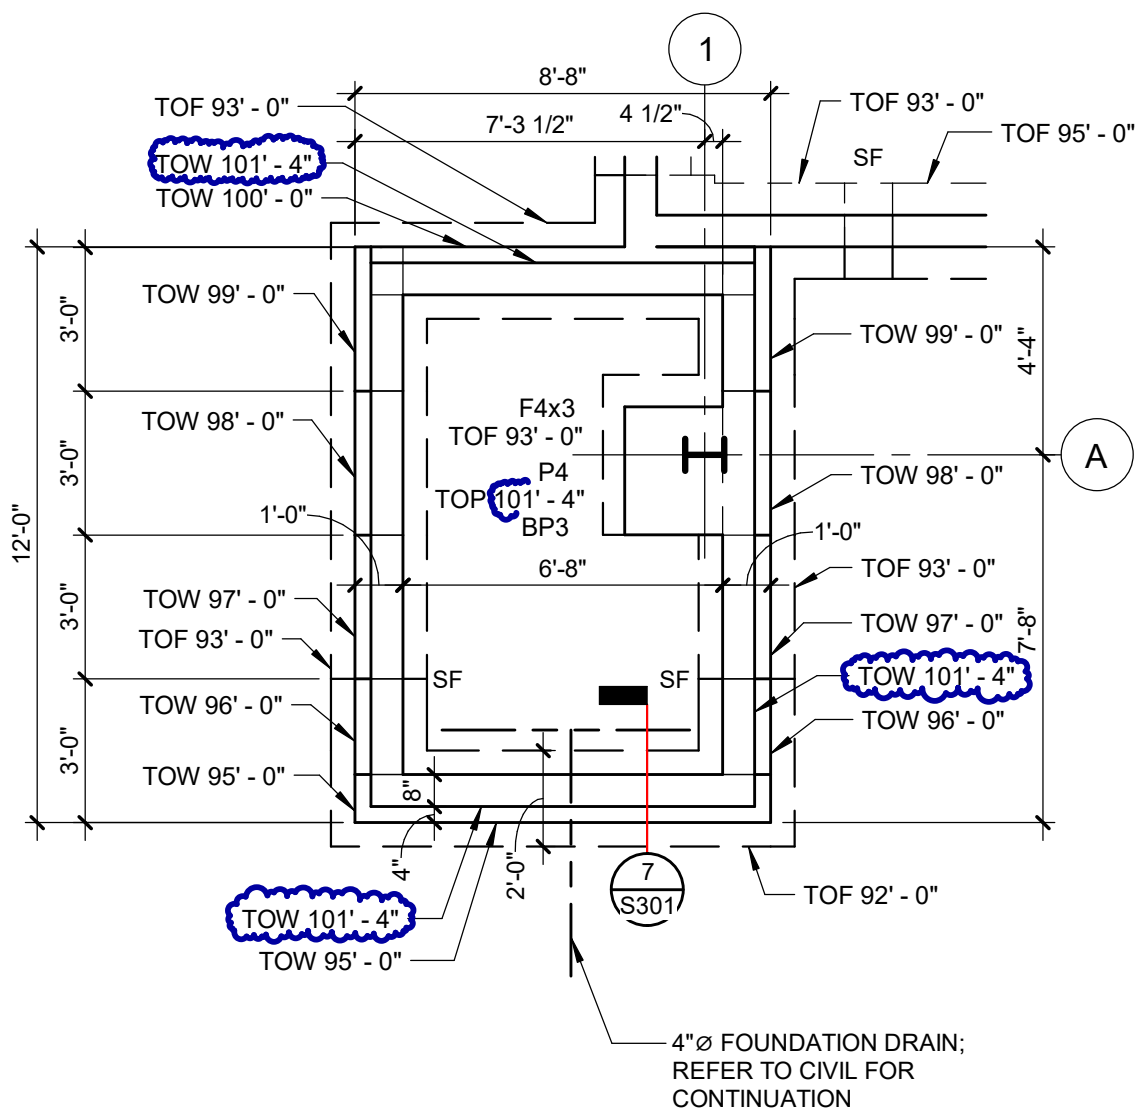

1 ENLARGED WEST FOUNDATION PLAN
SCALE: 1/4" = 1'-0"

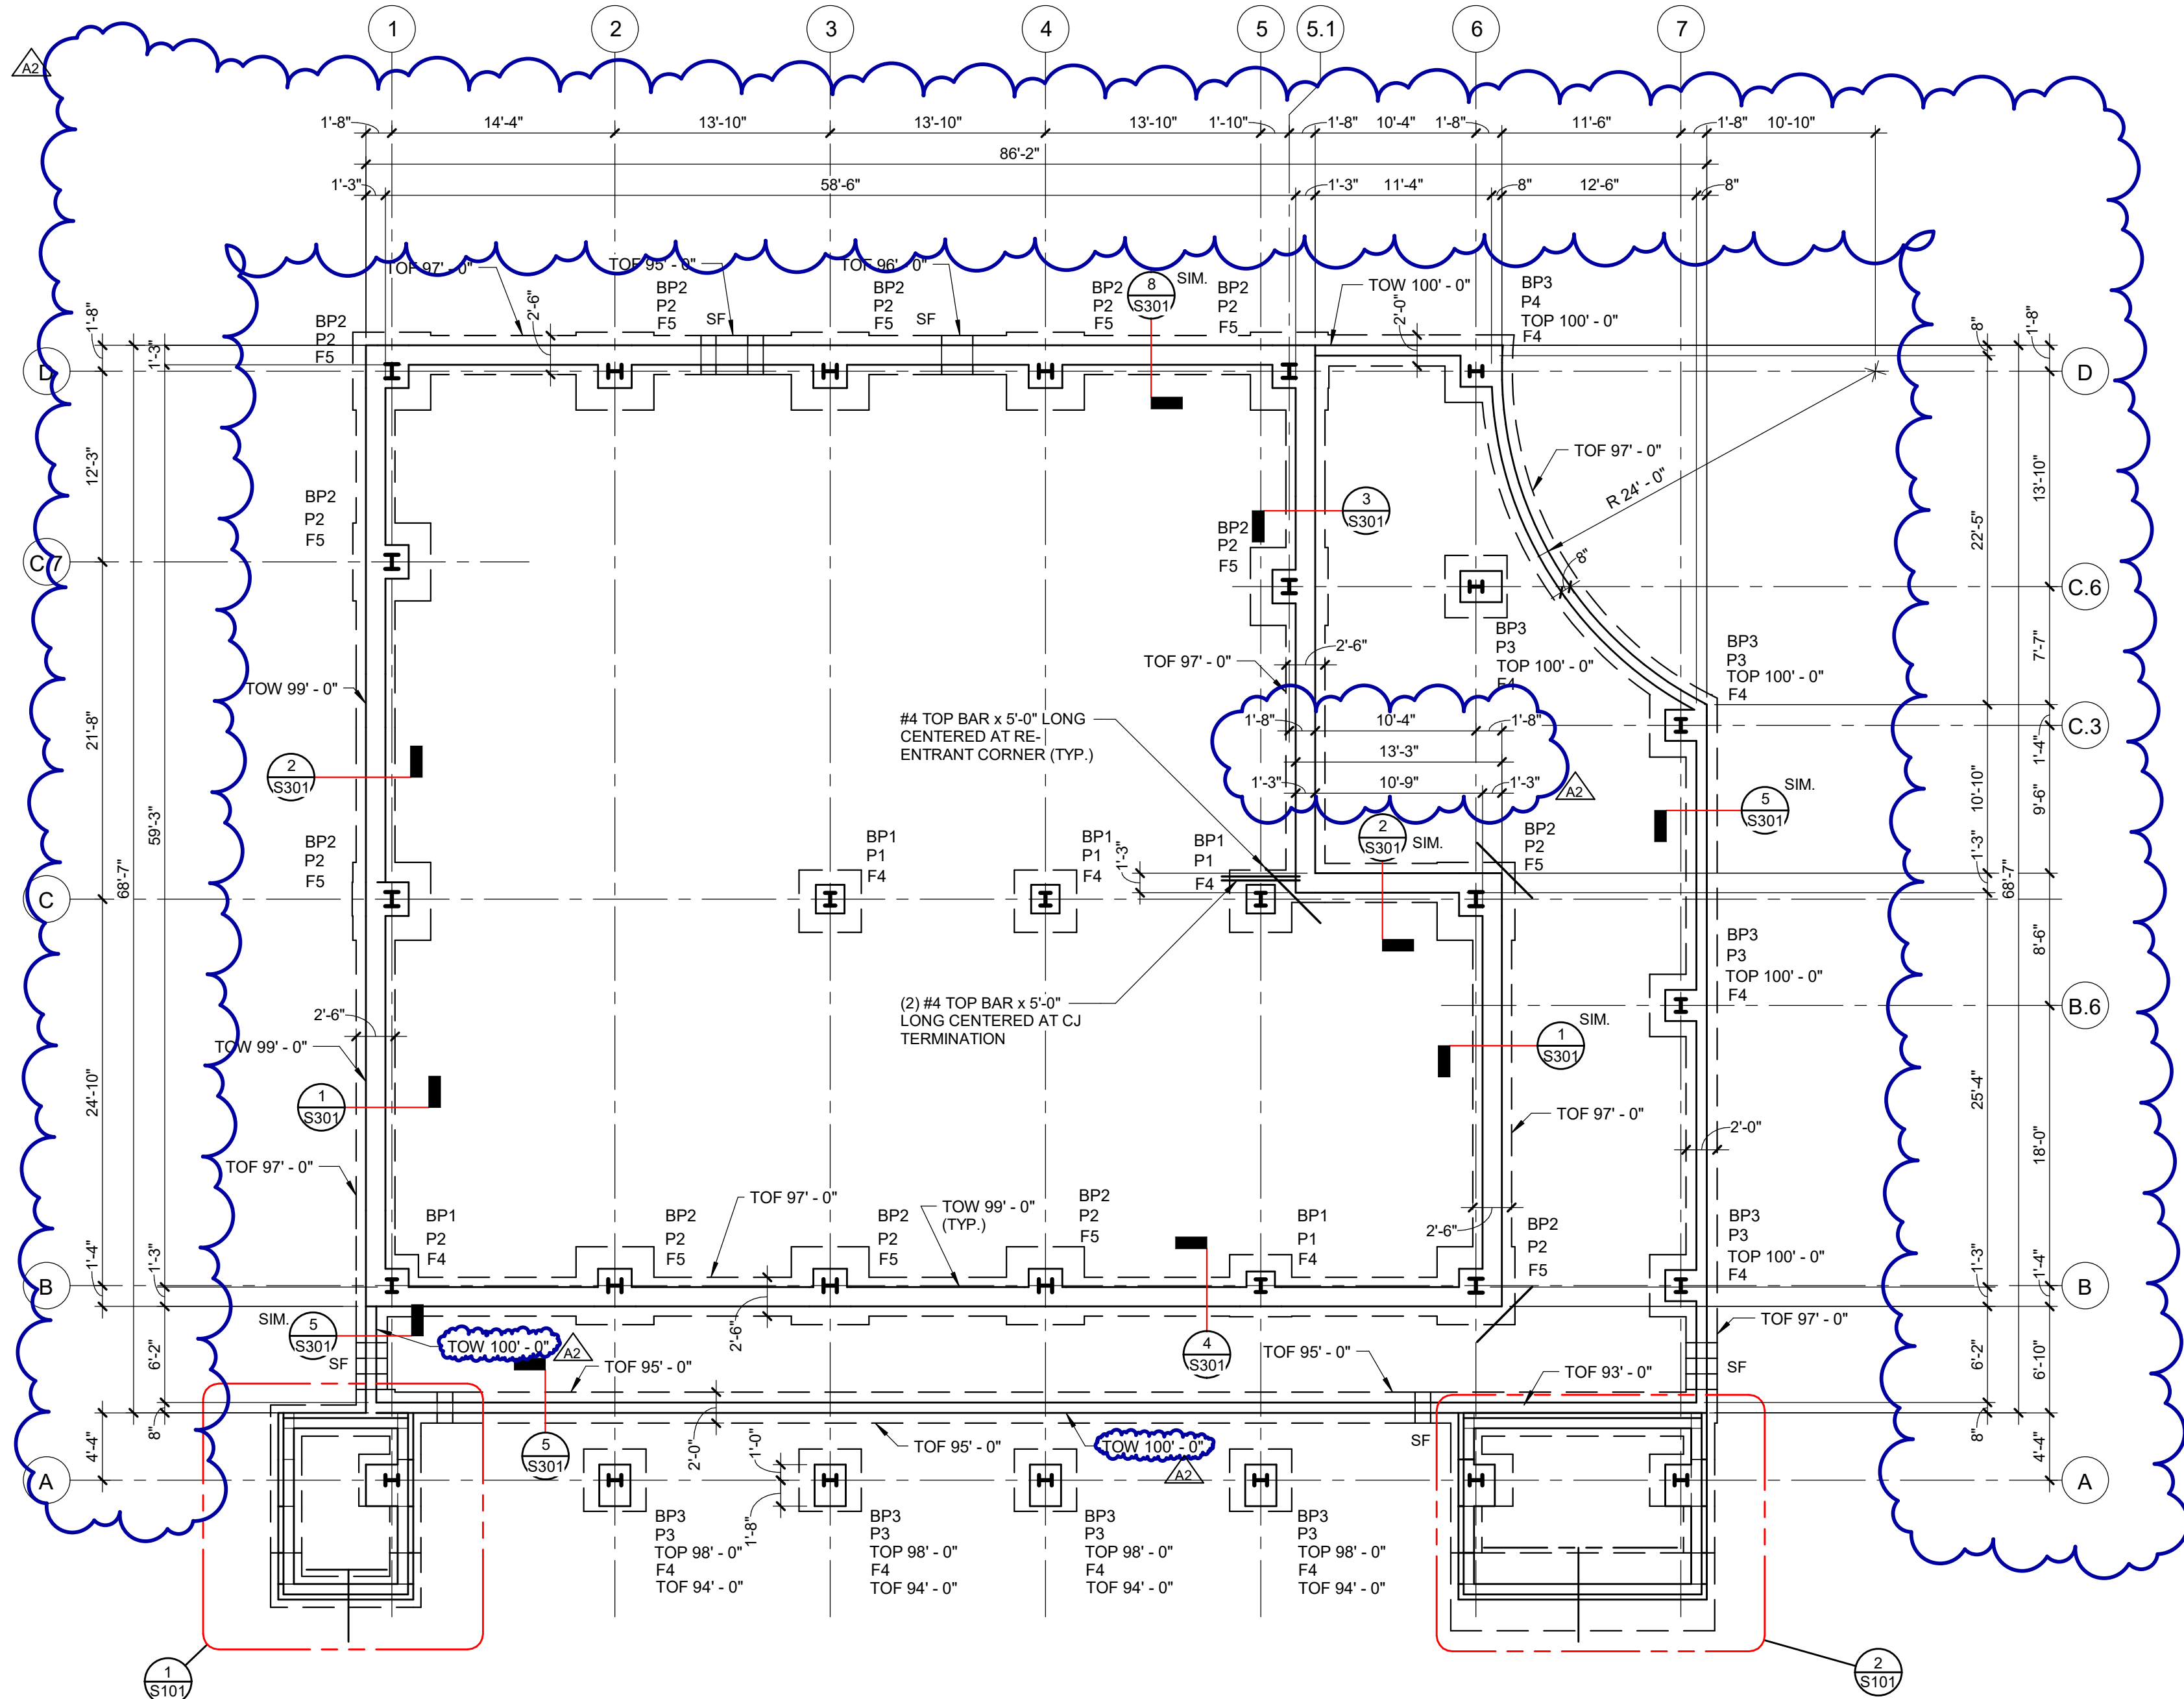

FOUNDATION PLAN - AREA A

SCALE: 1/8" = 1'-0"

KEY PLAN

AREA A



Van Buren Charter Township

Van Buren Township, MI

The Lakeside Park

fishbeck
Engineers | Architects | Scientists | Constructors

REVISIONS		
10/27/2022	A2	ADDENDUM NO. 2

10/12/2026	BIDS & PERMIT
09/21/2026	CD PEER REVIEW
09/09/2026	CD TEAM REVIEW
08/10/2026	CD 50% PROGRESS
08/22/2026	DD OWNER REVIEW
06/15/2026	DD PEER REVIEW
06/08/2026	DD 90% PROGRESS
05/18/2026	DD 50% PROGRESS
02/23/2026	SD OWNER REVIEW
02/13/2026	SD PEER REVIEW
02/09/2026	SD PROGRESS REVIEW

Drawn By	RMEISSNER
Designer	JCARTER
Reviewer	CJOTTE
Manager	CKRETOVIC

Hard copy is intended to be 24"x36" when plotted. Scale(s) indicated and graphic quality may not be accurate for any other size.

PROJECT NO.
2500281

SHEET NO.

S101

©Copyright 2026
All Rights Reserved

Van Buren Township, MI

The Lakeside Park

REVISIONS		
10/27/2022	A2	ADDENDUM NO. 2

10/12/2026	BIDS & PERMIT
09/21/2026	CD PEER REVIEW
09/09/2026	CD TEAM REVIEW
08/10/2026	CD 50% PROGRESS
06/22/2026	DD OWNER REVIEW
06/15/2026	DD PEER REVIEW
06/08/2026	DD 90 % PROGRESS
05/18/2026	DD 50 % PROGRESS
02/23/2026	SD OWNER REVIEW
02/13/2026	SD PEER REVIEW
02/09/2026	SD PROGRESS REVIEW

Drawn By	RMEISSNER
Designer	JCARTER
Reviewer	CJOTTE
Manager	CKRETOVIC

Hard copy is intended to be 24"x36" when plotted. Scale(s) indicated and graphic quality may not be accurate for any other size.



PROJECT NO.
2500281

SHEET NO.


S102


©Copyright 2026
All Rights Reserved

- # NOTES
1. TOP OF PIER ELEVATION = 99'-0", UNLESS NOTED OTHERWISE.
 2. TOP OF FOOTING ELEVATION = 97'-0", UNLESS NOTED OTHERWISE.
 3. TOP OF WALL ELEVATION = 99'-0" UNLESS NOTED OTHERWISE.
- 
4. REFER TO S101 FOR BASE PLATE, PIER, AND FOOTING SCHEDULES.
 5. REFER TO CIVIL AND ARCHITECTURAL FOR EXTERIOR SLABS AND STAIRS.

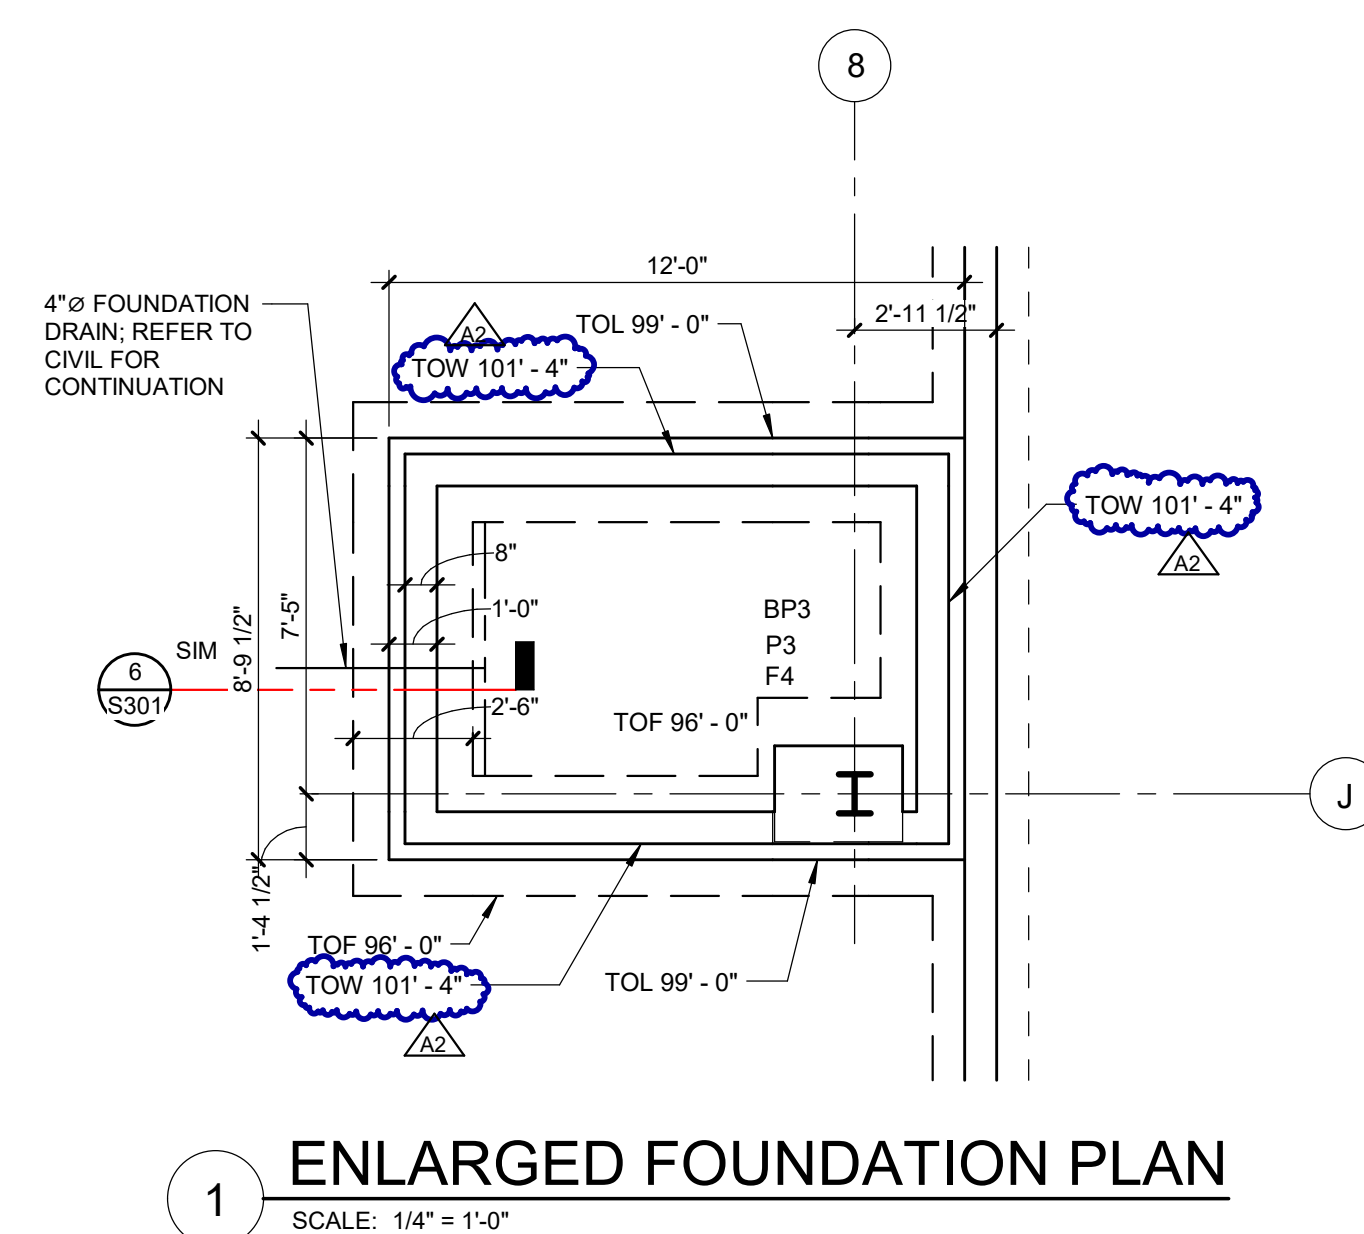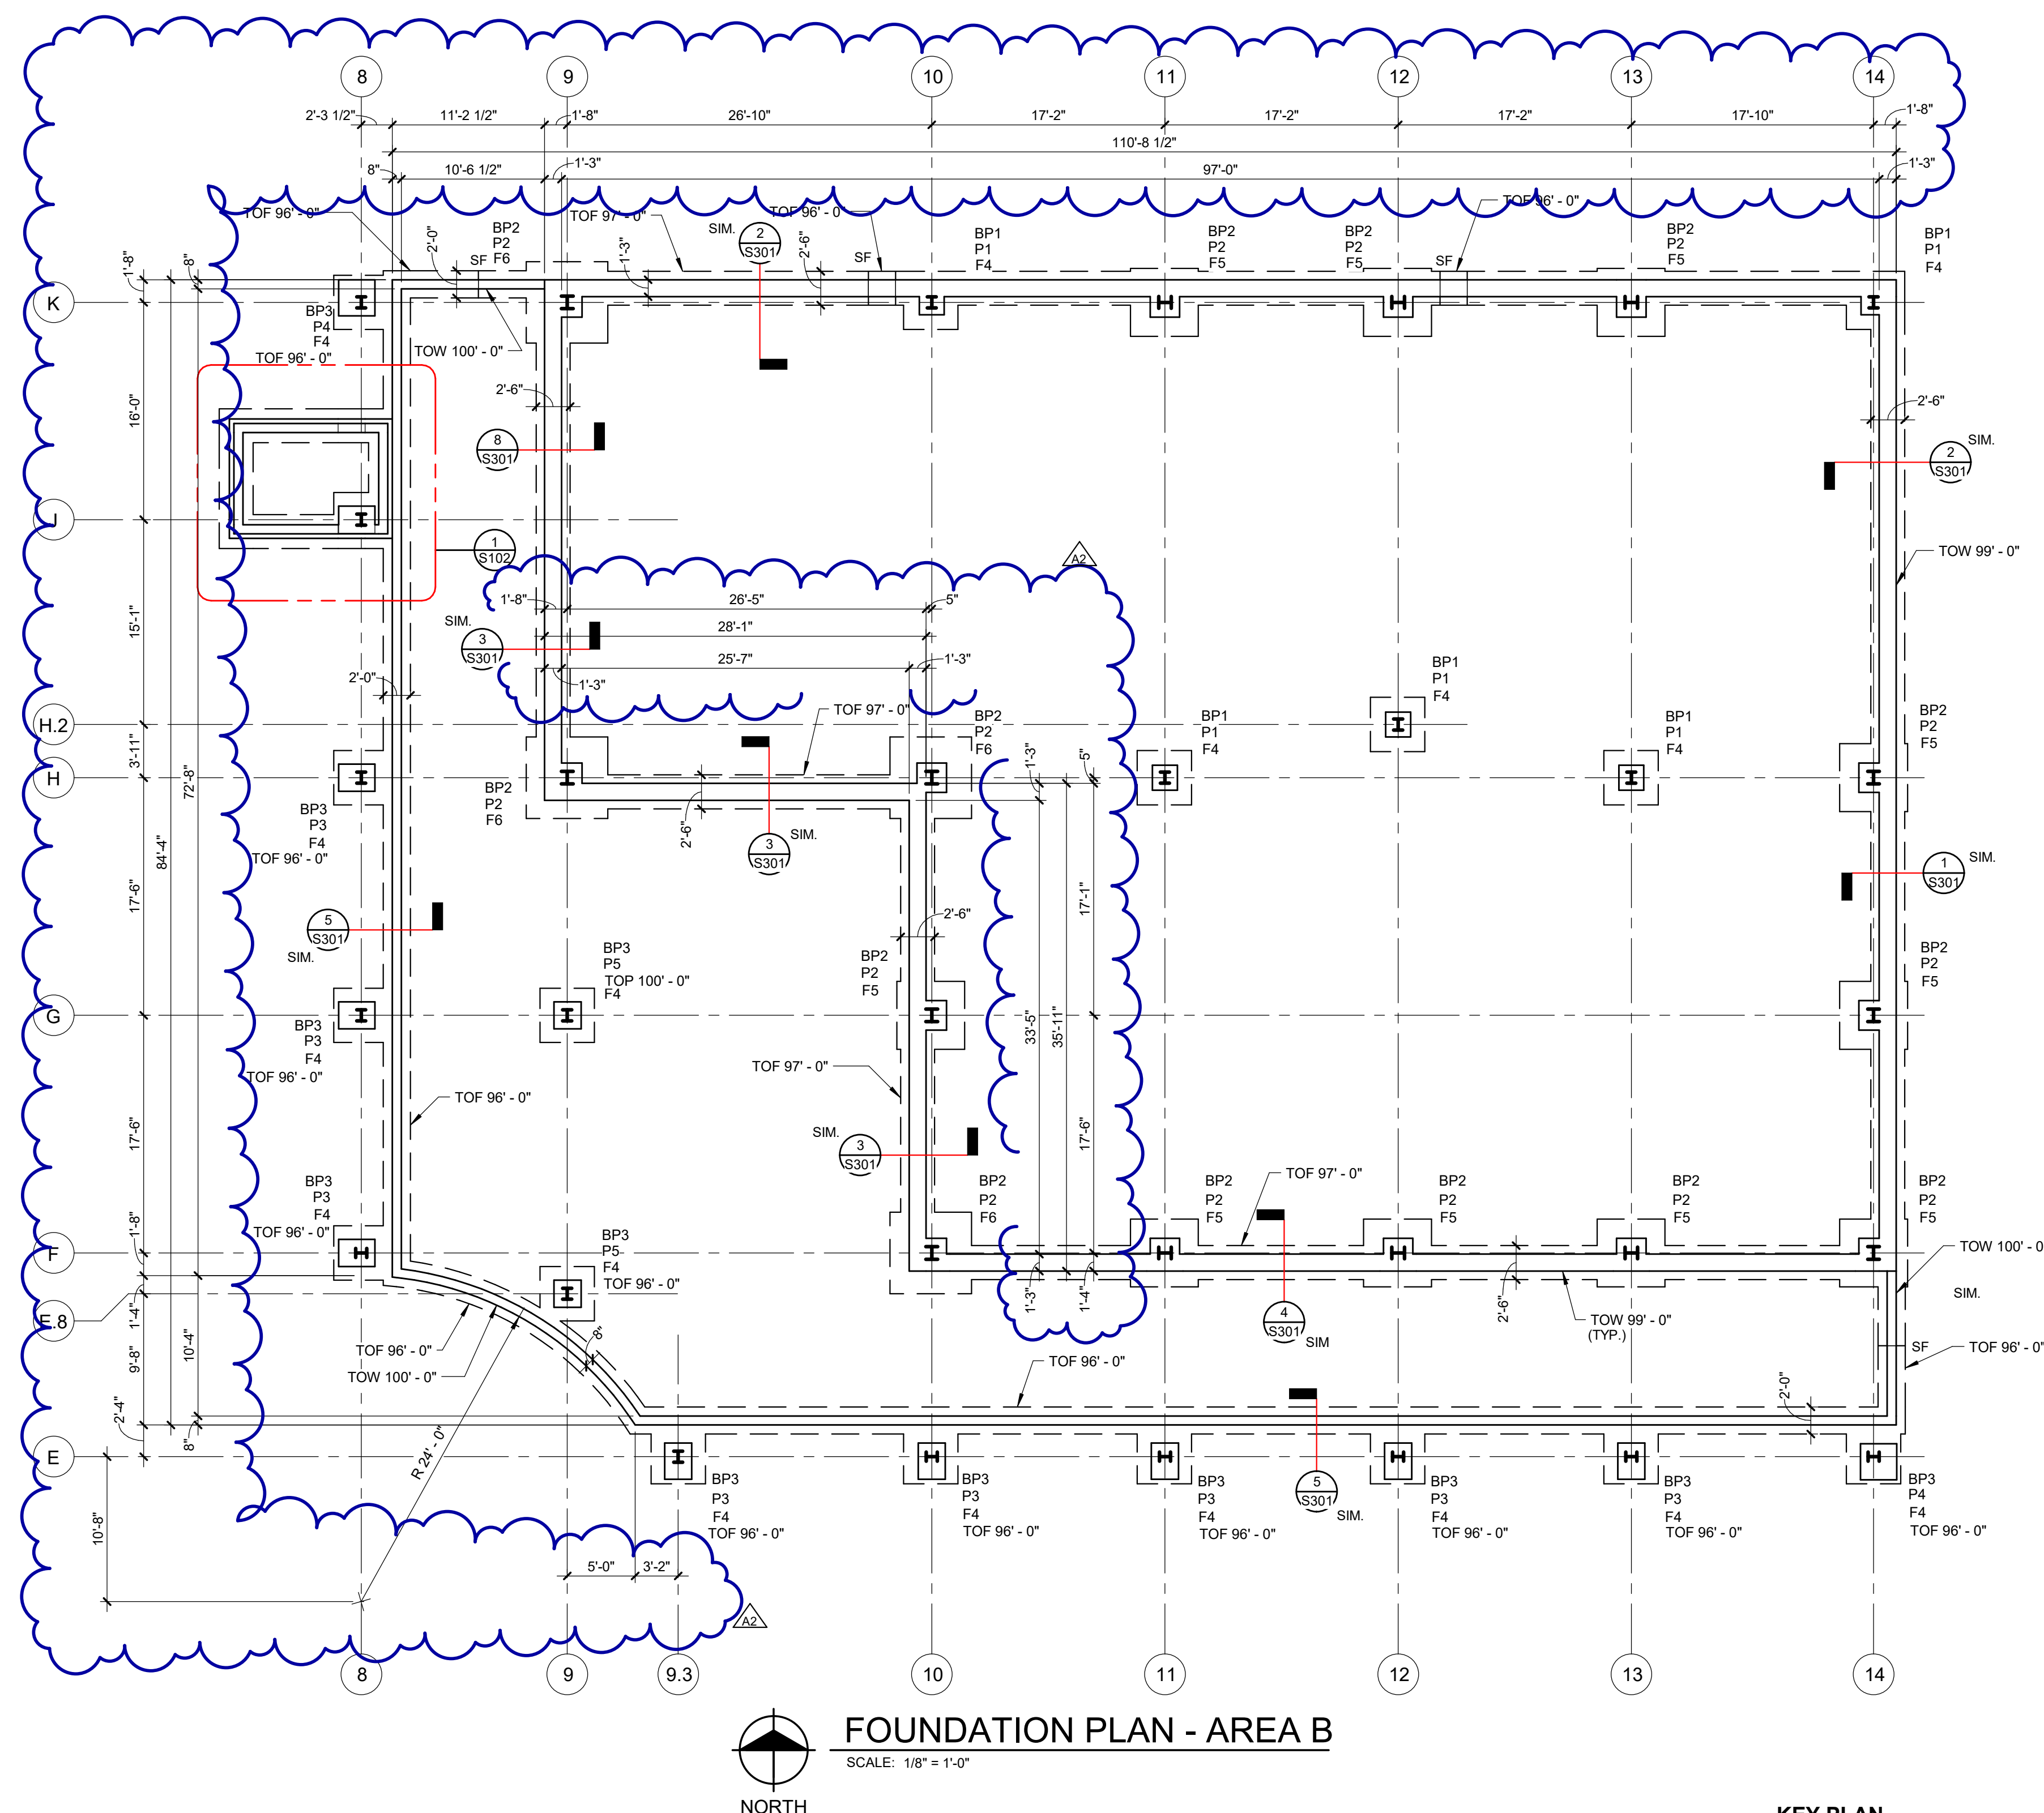

KEY PLAN

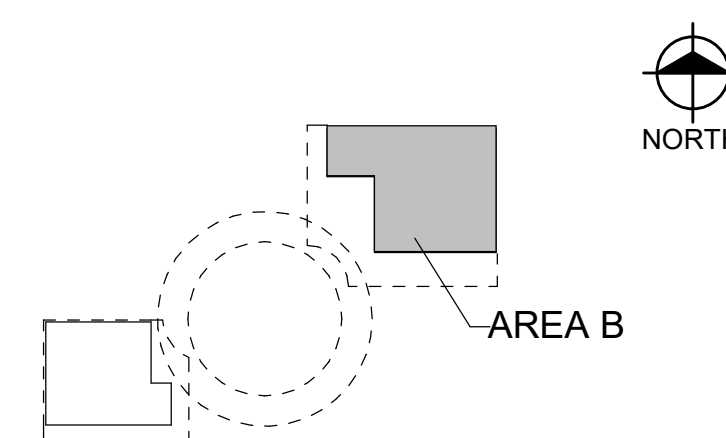

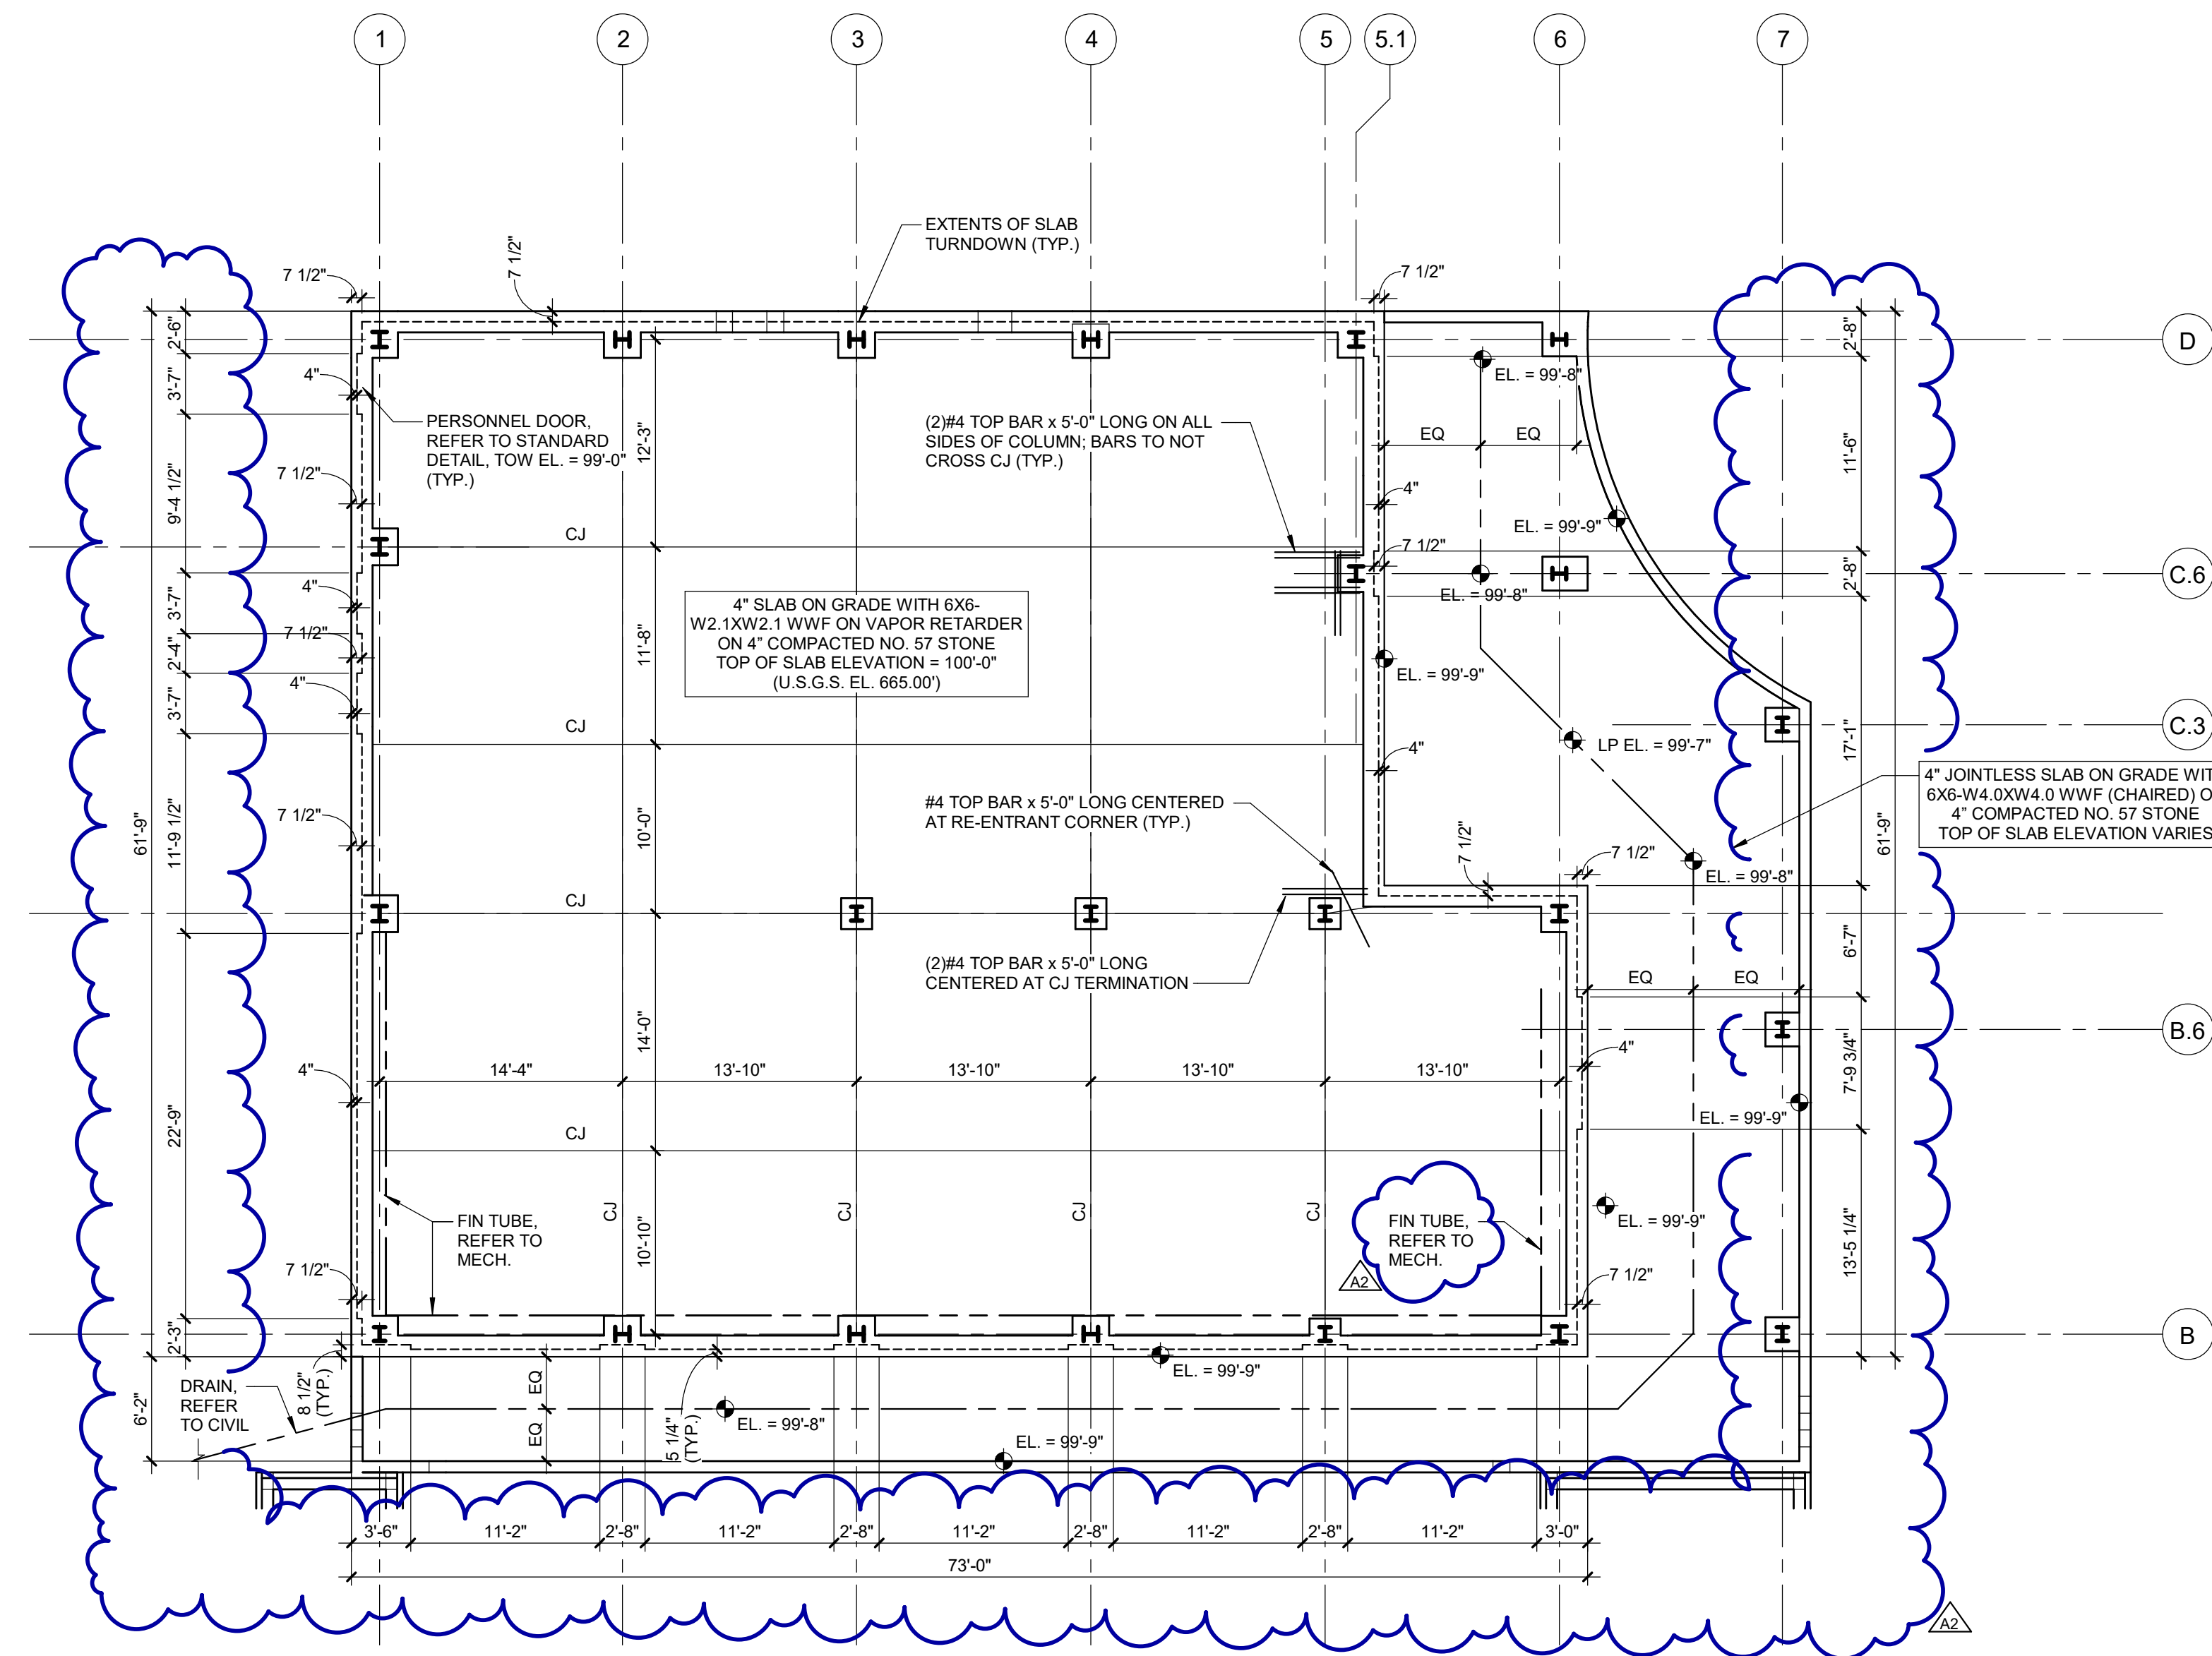


SLAB PLAN - AREA A

SCALE: 1/8" = 1'-0"



KEY PLAN

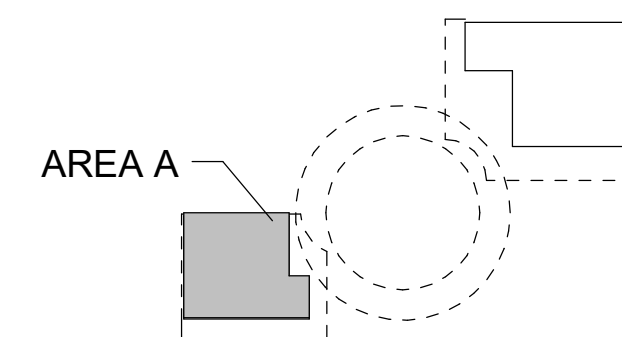

NORTH

REVISIONS		
10/27/2022	A2	ADDENDUM NO. 2

10/12/2026	BIDS & PERMIT
09/21/2026	CD PEER REVIEW
09/09/2026	CD TEAM REVIEW
08/10/2026	CD 50% PROGRESS
06/22/2026	DD OWNER REVIEW
06/15/2026	DD PEER REVIEW
06/08/2026	DD 90 % PROGRESS
05/18/2026	DD 50 % PROGRESS
02/23/2026	SD OWNER REVIEW
02/13/2026	SD PEER REVIEW
02/09/2026	SD PROGRESS REVIEW


Drawn By	RMEISSNER
Designer	JCARTER
Reviewer	CJOTTE
Manager	CKRETOVIC

Hard copy is intended to be 24"x36" when plotted. Scale(s) indicated and graphic quality may not be accurate for any other size.


PROJECT NO.
2500281

SHEET NO.

S104

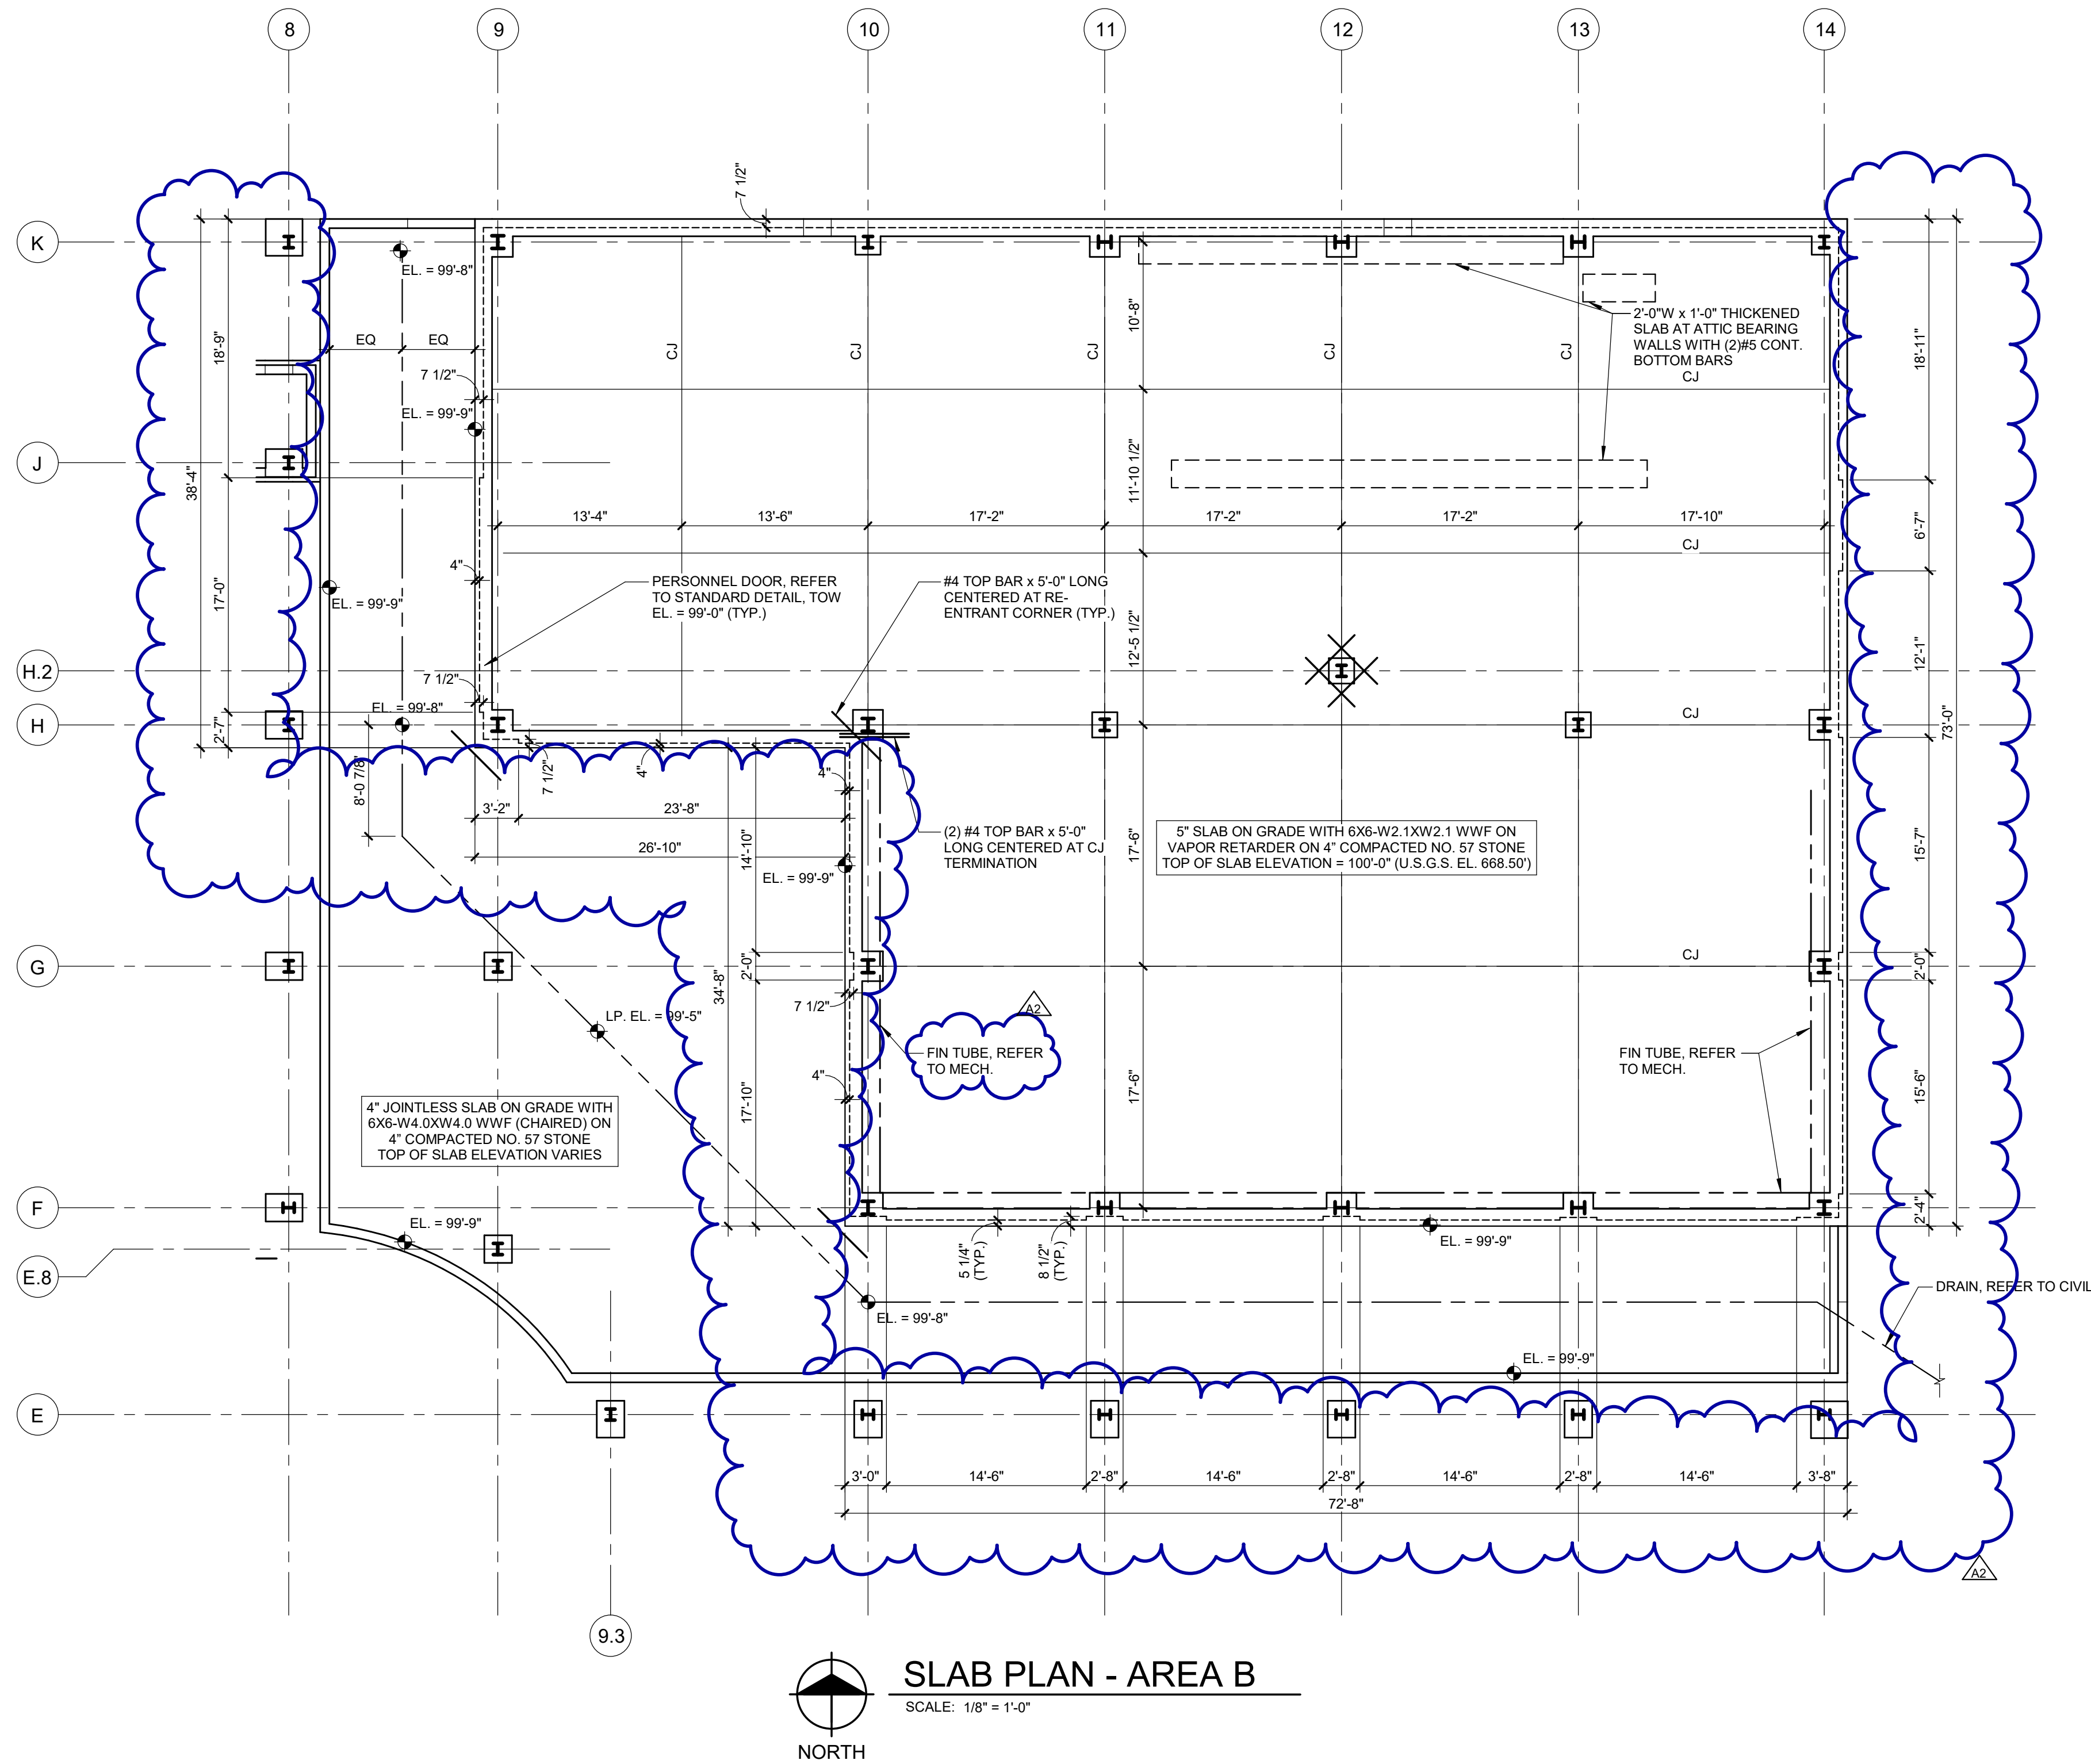

KEY PLAN

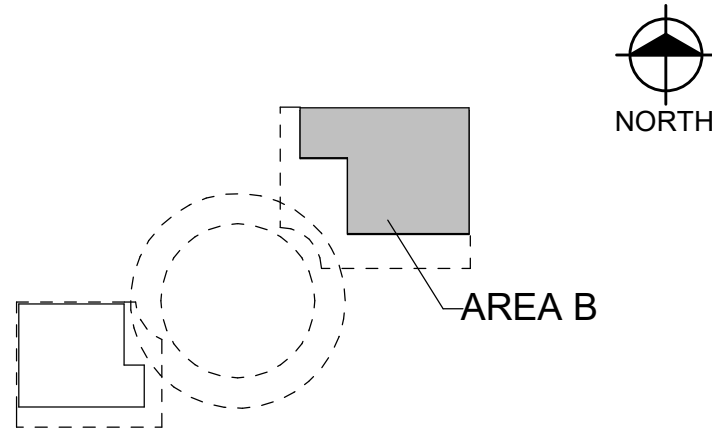

Van Buren Charter Township

Van Buren Township, MI

The Lakeside Park

REVISIONS		
10/27/2022	A2	ADDENDUM NO. 2

10/12/2026	BIDS & PERMIT
09/21/2026	CD PEER REVIEW
09/09/2026	CD TEAM REVIEW
08/10/2026	CD 50% PROGRESS
08/22/2026	DD OWNER REVIEW
06/15/2026	DD PEER REVIEW
06/08/2026	DD 90 % PROGRESS
05/18/2026	DD 50 % PROGRESS
02/23/2026	SD OWNER REVIEW
02/13/2026	SD PEER REVIEW
02/09/2026	SD PROGRESS REVIEW


Drawn By RMEISSNER
Designer JCARTER
Reviewer CJOTTE
Manager CKRETOVIC

Hard copy is intended to be 24"x36" when plotted. Scale(s) indicated and graphic quality may not be accurate for any other size.

PROJECT NO.
2500281

SHEET NO.

S105

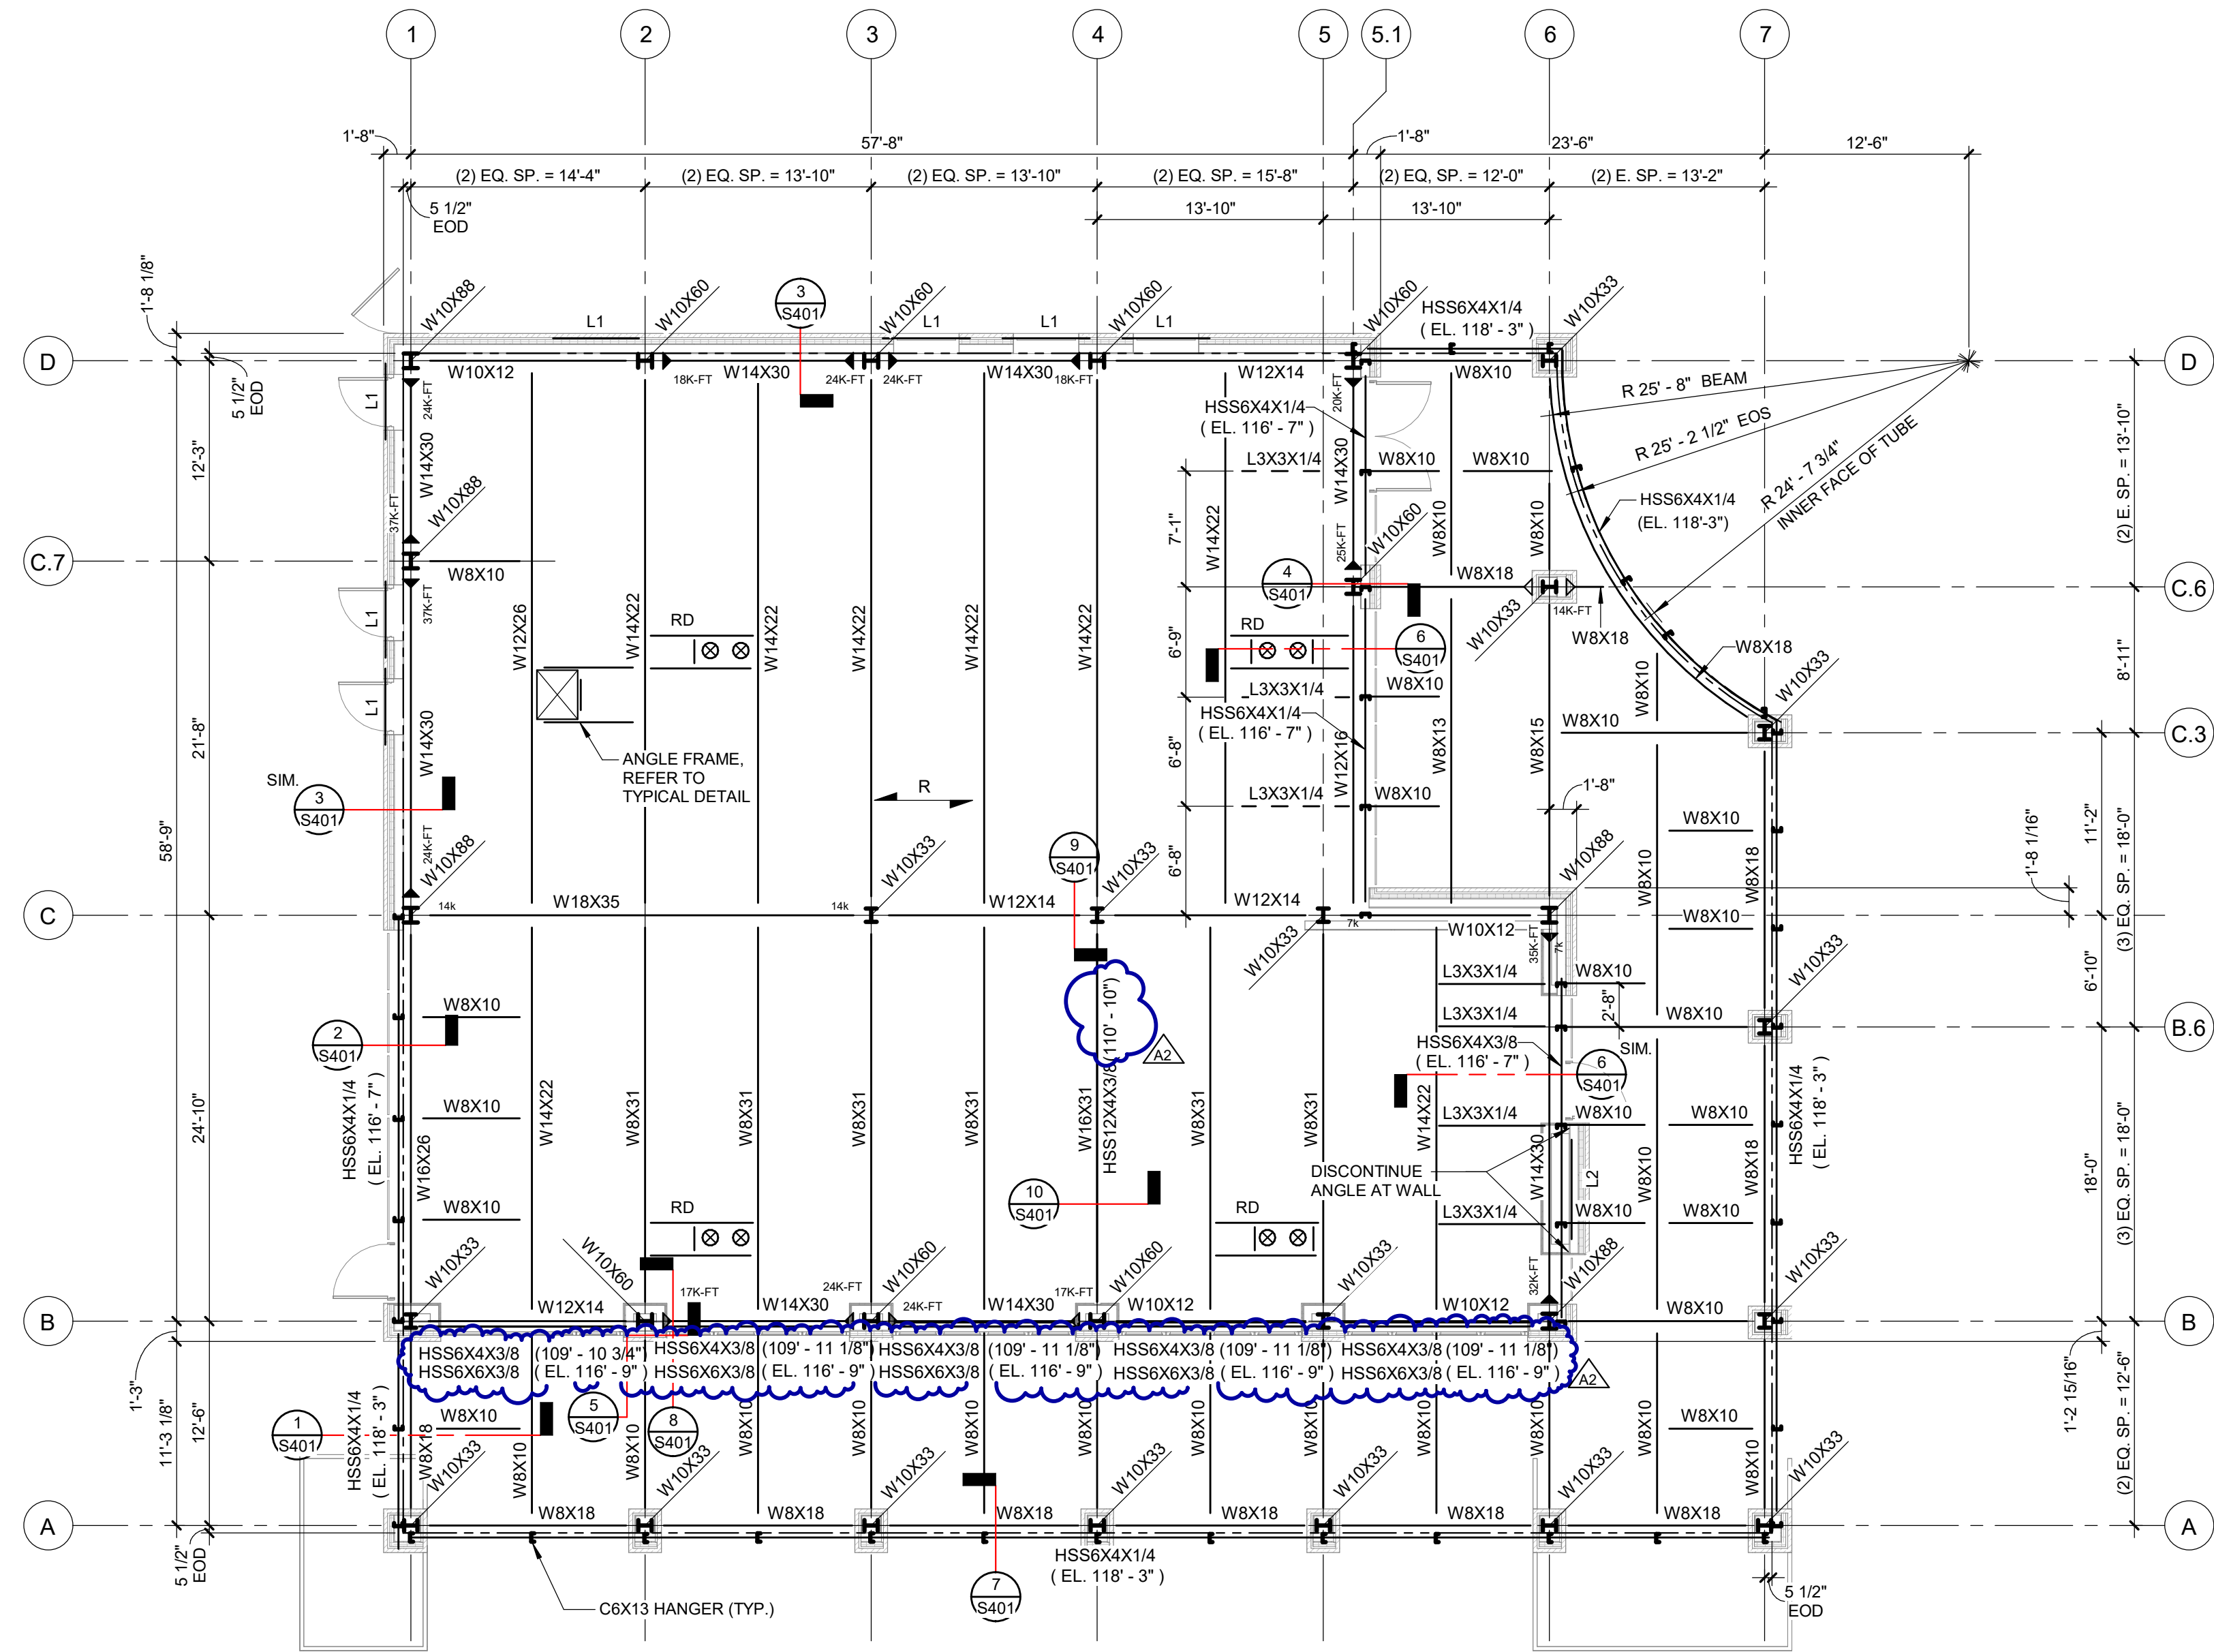


ROOF FRAMING PLAN - AREA A

SCALE: 1/8" = 1'-0"

KEY PLAN

AREA A

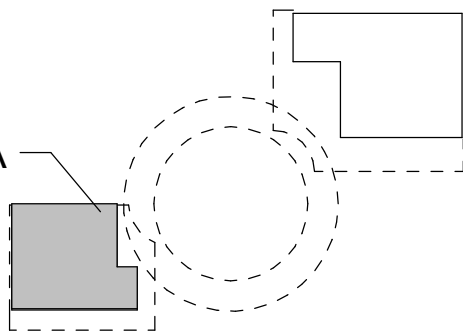

NOTES

1. TOP OF STEEL ELEVATION = 119'-2", UNLESS NOTED OTHERWISE.
2. EXTERIOR COLUMNS, BEAMS, HANGER ASSEMBLY, AND ASSOCIATED CONNECTIONS TO BE HOT-DIP GALVANIZED AFTER FABRICATION. TOUCH UP ALL DAMAGED GALVANIZED AREAS WITH A ZINC-RICH PAINT.
3. PROVIDE 3/8" DIAMETER TYPE 304 STAINLESS STEEL DOWEL PINS AT HANGER ASSEMBLY LIMESTONE BEARING LOCATIONS. PINS TO BE WELDED AND TO PROJECT 2" ABOVE HORIZONTAL LEG OF LINTEL ANGLE AND TO BE EMBEDDED 1-1/2" MINIMUM INTO LIMESTONE. COORDINATE PIN SPACING WITH LIMESTONE FABRICATOR'S SHOP DRAWINGS. REPAIR DAMAGED GALVANIZED COATING WITH ZINC-RICH PAINT.
4. FABRICATE CURVED MEMBERS TO A UNIFORM RADIUS SUCH THAT THE MAXIMUM DEVIATION OF THE MEMBER CENTERLINE FROM THE THEORETICAL CURVE SHALL NOT EXCEED +/- 1/4 INCH OVER THE FULL LENGTH OF THE MEMBER. MEMBERS TO BE FREE OF KINKS, LOCAL BUCKLES, OR OTHER DEFORMATIONS. TOTAL TWIST SHALL NOT EXCEED 1 DEGREE IN ANY 20 FEET OF MEMBER LENGTH. FOR HSS MEMBERS, CROSS-SECTIONAL DISTORTION TO NOT EXCEED 3% OF THE NOMINAL MEMBER DIMENSION. TOTAL TWIST SHALL NOT EXCEED 1 DEGREE IN ANY 20 FEET OF MEMBER LENGTH.

Van Buren Charter Township

Van Buren Township, MI

The Lakeside Park

REVISIONS

NO.	DATE	DESCRIPTION
1	10/27/2022	A2 [ADDENDUM NO. 2]

10/12/2026	BIDS & PERMIT
09/21/2026	CD PEER REVIEW
09/09/2026	CD TEAM REVIEW
08/10/2026	CD 50% PROGRESS
08/22/2026	DD OWNER REVIEW
06/15/2026	DD PEER REVIEW
06/08/2026	DD 90% PROGRESS
05/18/2026	DD 50% PROGRESS
02/23/2026	SD OWNER REVIEW
02/13/2026	SD PEER REVIEW
02/09/2026	SD PROGRESS REVIEW


Drawn By	RMEISSNER
Designer	JCARTER
Reviewer	CJOTTE
Manager	CKRETOVIC

Hard copy is intended to be 24"x36" when plotted. Scale(s) indicated and graphic quality may not be accurate for any other size.

PROJECT NO.
2500281

SHEET NO.


S201

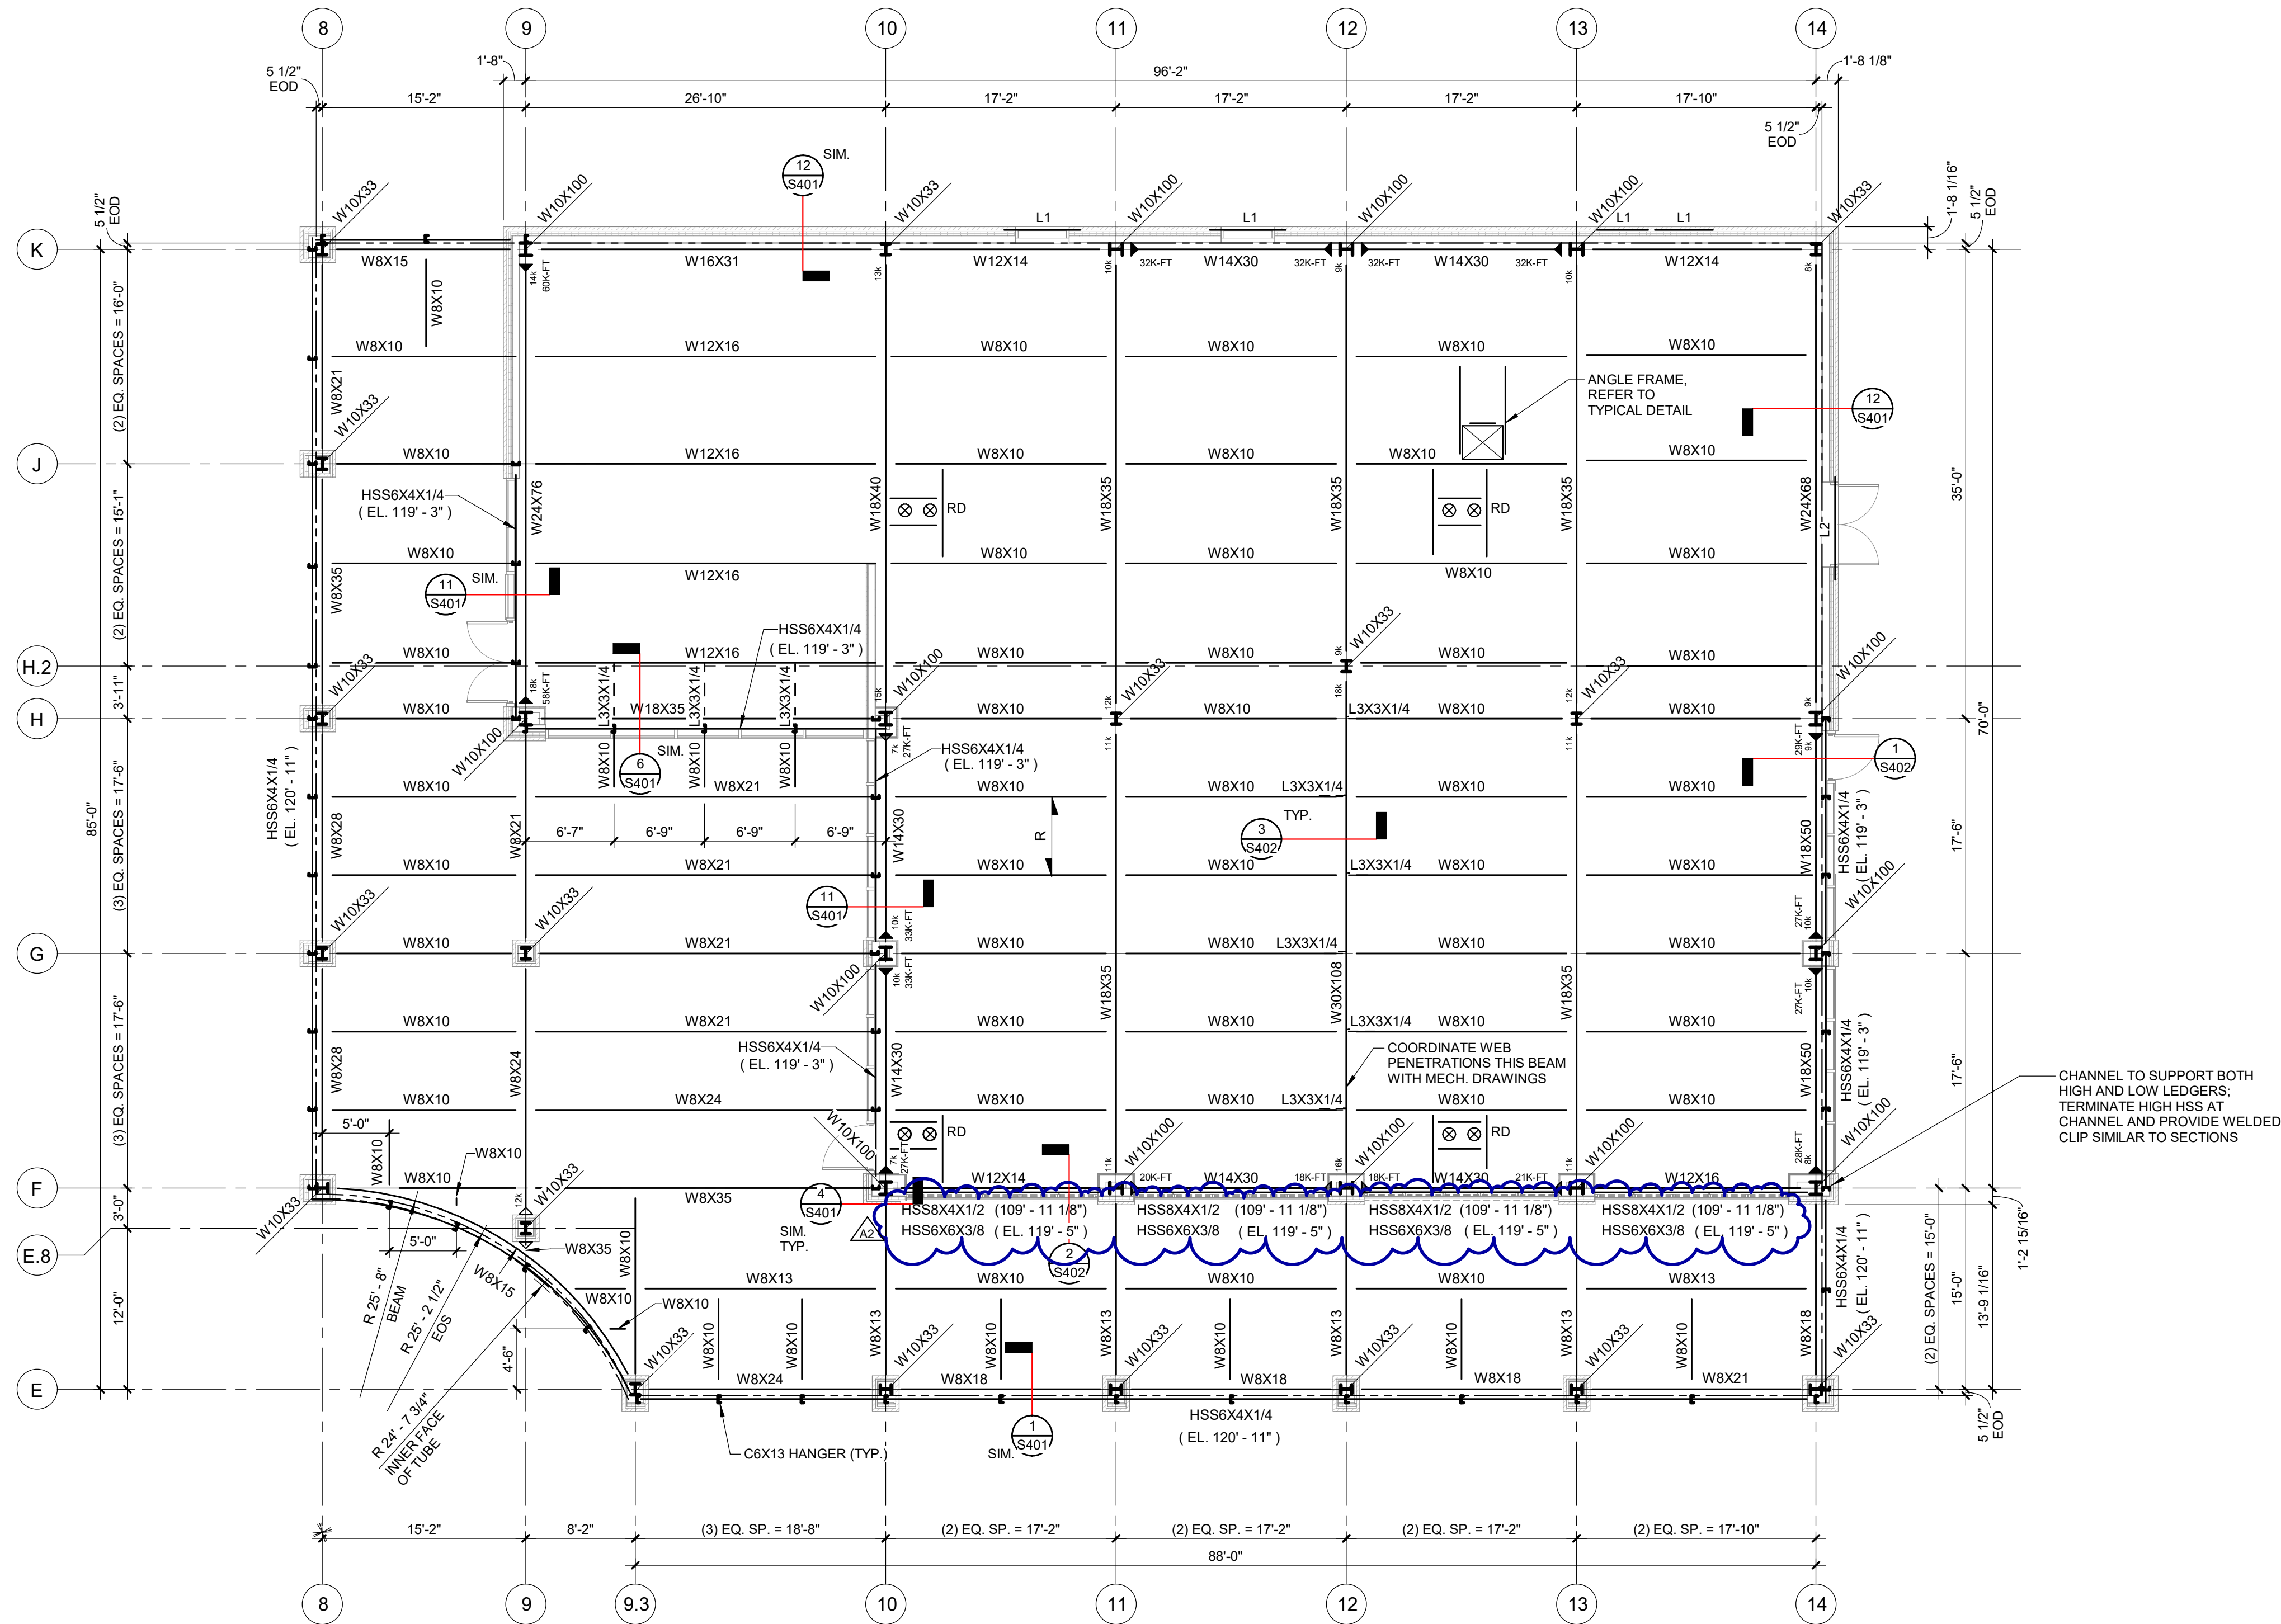

ROOF FRAMING PLAN - AREA B

SCALE: 1/8" = 1'-0"

KEY PLAN

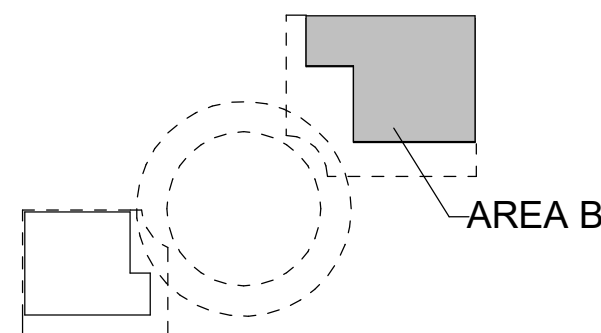

NOTES

- TOP OF STEEL ELEVATION = 121'-10", UNLESS NOTED OTHERWISE.
- EXTERIOR COLUMNS, BEAMS, HANGER ASSEMBLY, AND ASSOCIATED CONNECTIONS TO BE HOT-DIP GALVANIZED AFTER FABRICATION. TOUCH UP ALL DAMAGED GALVANIZED AREAS WITH A ZINC-RICH PAINT.
- PROVIDE 3/8" DIAMETER TYPE 304 STAINLESS STEEL DOWEL PINS AT HANGER ASSEMBLY LIMESTONE BEARING LOCATIONS. PINS TO BE WELDED AND TO PROJECT 2" ABOVE HORIZONTAL LEG OF LINTEL ANGLE AND TO BE EMBEDDED 1-1/2" MINIMUM INTO LIMESTONE. COORDINATE PIN SPACING WITH LIMESTONE FABRICATOR'S SHOP DRAWINGS. REPAIR DAMAGED GALVANIZED COATING WITH ZINC-RICH PAINT.
- FABRICATE CURVED MEMBERS TO A UNIFORM RADIUS SUCH THAT THE MAXIMUM DEVIATION OF THE MEMBER CENTERLINE FROM THE THEORETICAL CURVE SHALL NOT EXCEED +/- 1/4 INCH OVER THE FULL LENGTH OF THE MEMBER. MEMBERS TO BE FREE OF KINKS, LOCAL BUCKLES, OR OTHER DEFORMATIONS. TOTAL TWIST SHALL NOT EXCEED 1 DEGREE IN ANY 20 FEET OF MEMBER LENGTH. FOR HSS MEMBERS, CROSS-SECTIONAL DISTORTION TO NOT EXCEED 3% OF THE NOMINAL MEMBER DIMENSION. TOTAL TWIST SHALL NOT EXCEED 1 DEGREE IN ANY 20 FEET OF MEMBER LENGTH.

Van Buren Charter Township

Van Buren Township, MI

The Lakeside Park

REVISIONS

NO.	DATE	DESCRIPTION
1	10/27/2022	A2 [ADDENDUM NO. 2]

10/12/2026	BIDS & PERMIT
09/21/2026	CD PEER REVIEW
09/09/2026	CD TEAM REVIEW
08/10/2026	CD 50% PROGRESS
06/22/2026	DD OWNER REVIEW
06/15/2026	DD PEER REVIEW
06/08/2026	DD 90% PROGRESS
05/18/2026	DD 50% PROGRESS
02/23/2026	SD OWNER REVIEW
02/13/2026	SD PEER REVIEW
02/09/2026	SD PROGRESS REVIEW









Drawn By RMEISSNER
Designer JCARTER
Reviewer CJOTTE
Manager CKRETOVIC

Hard copy is intended to be 24"x36" when plotted. Scale(s) indicated and graphic quality may not be accurate for any other size.

PROJECT NO.
2500281

SHEET NO.

S202

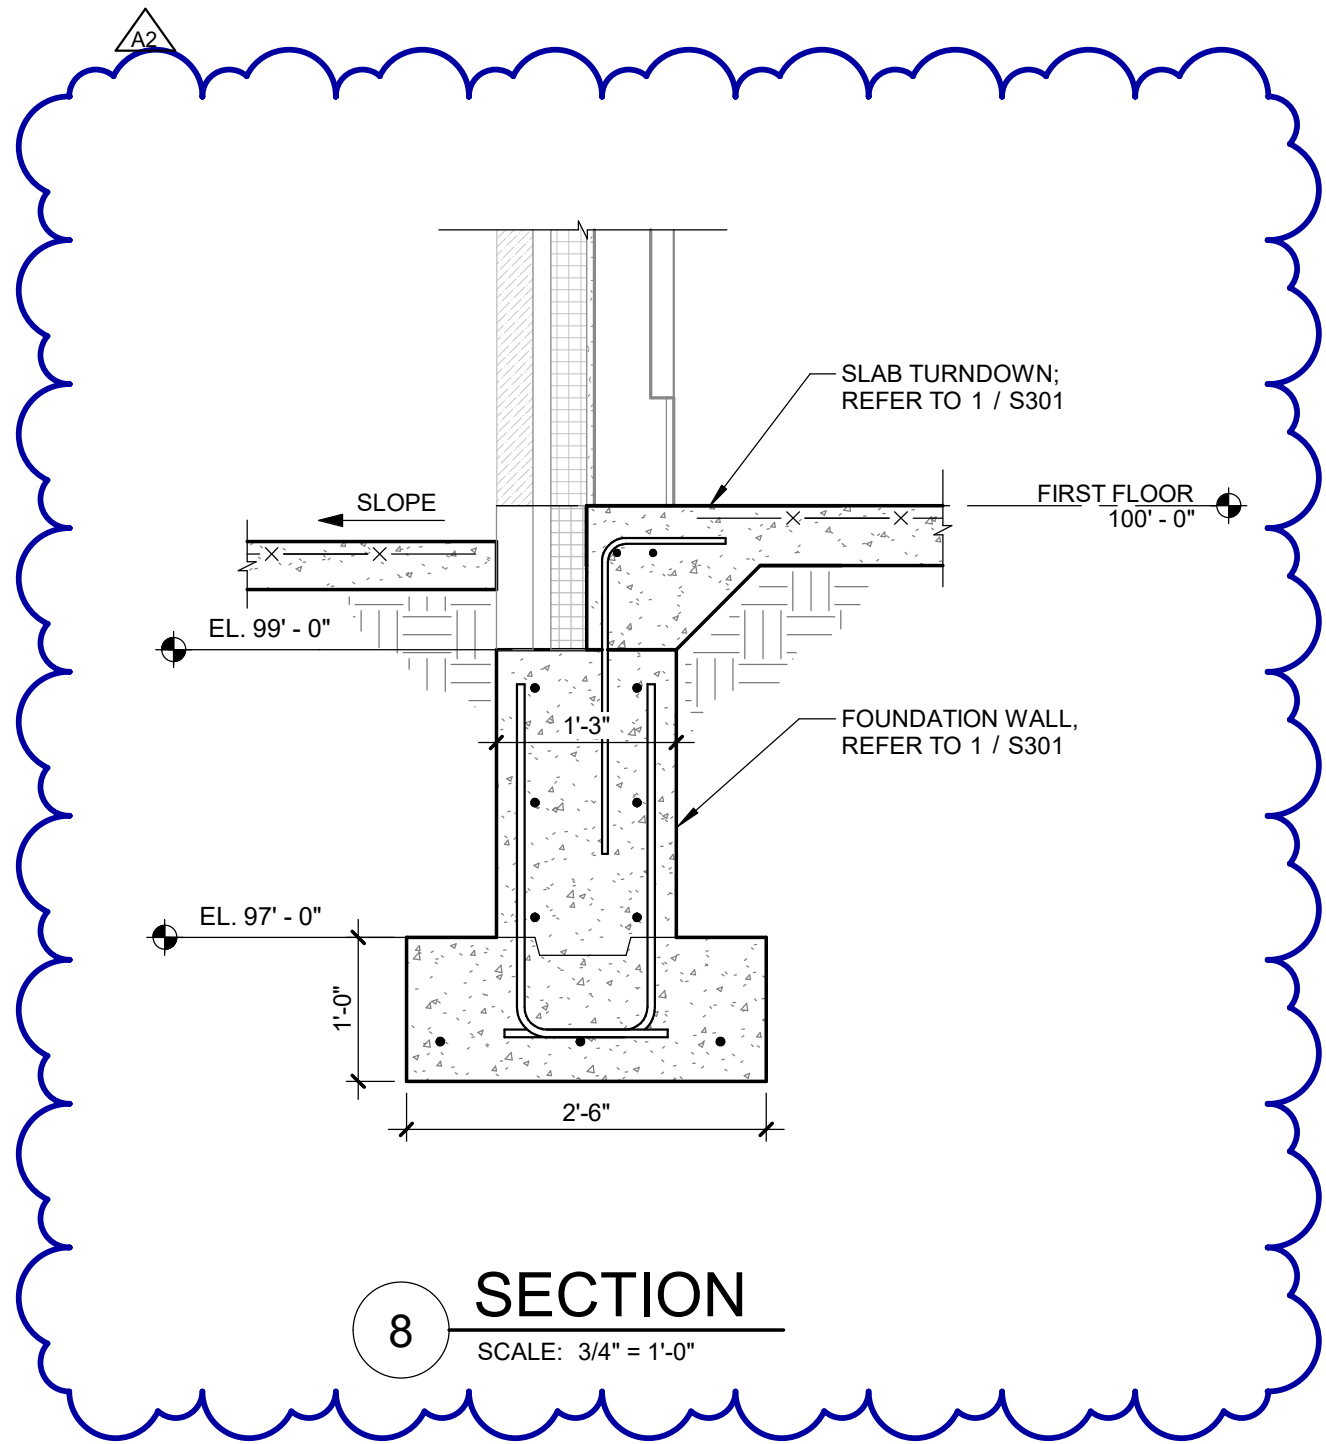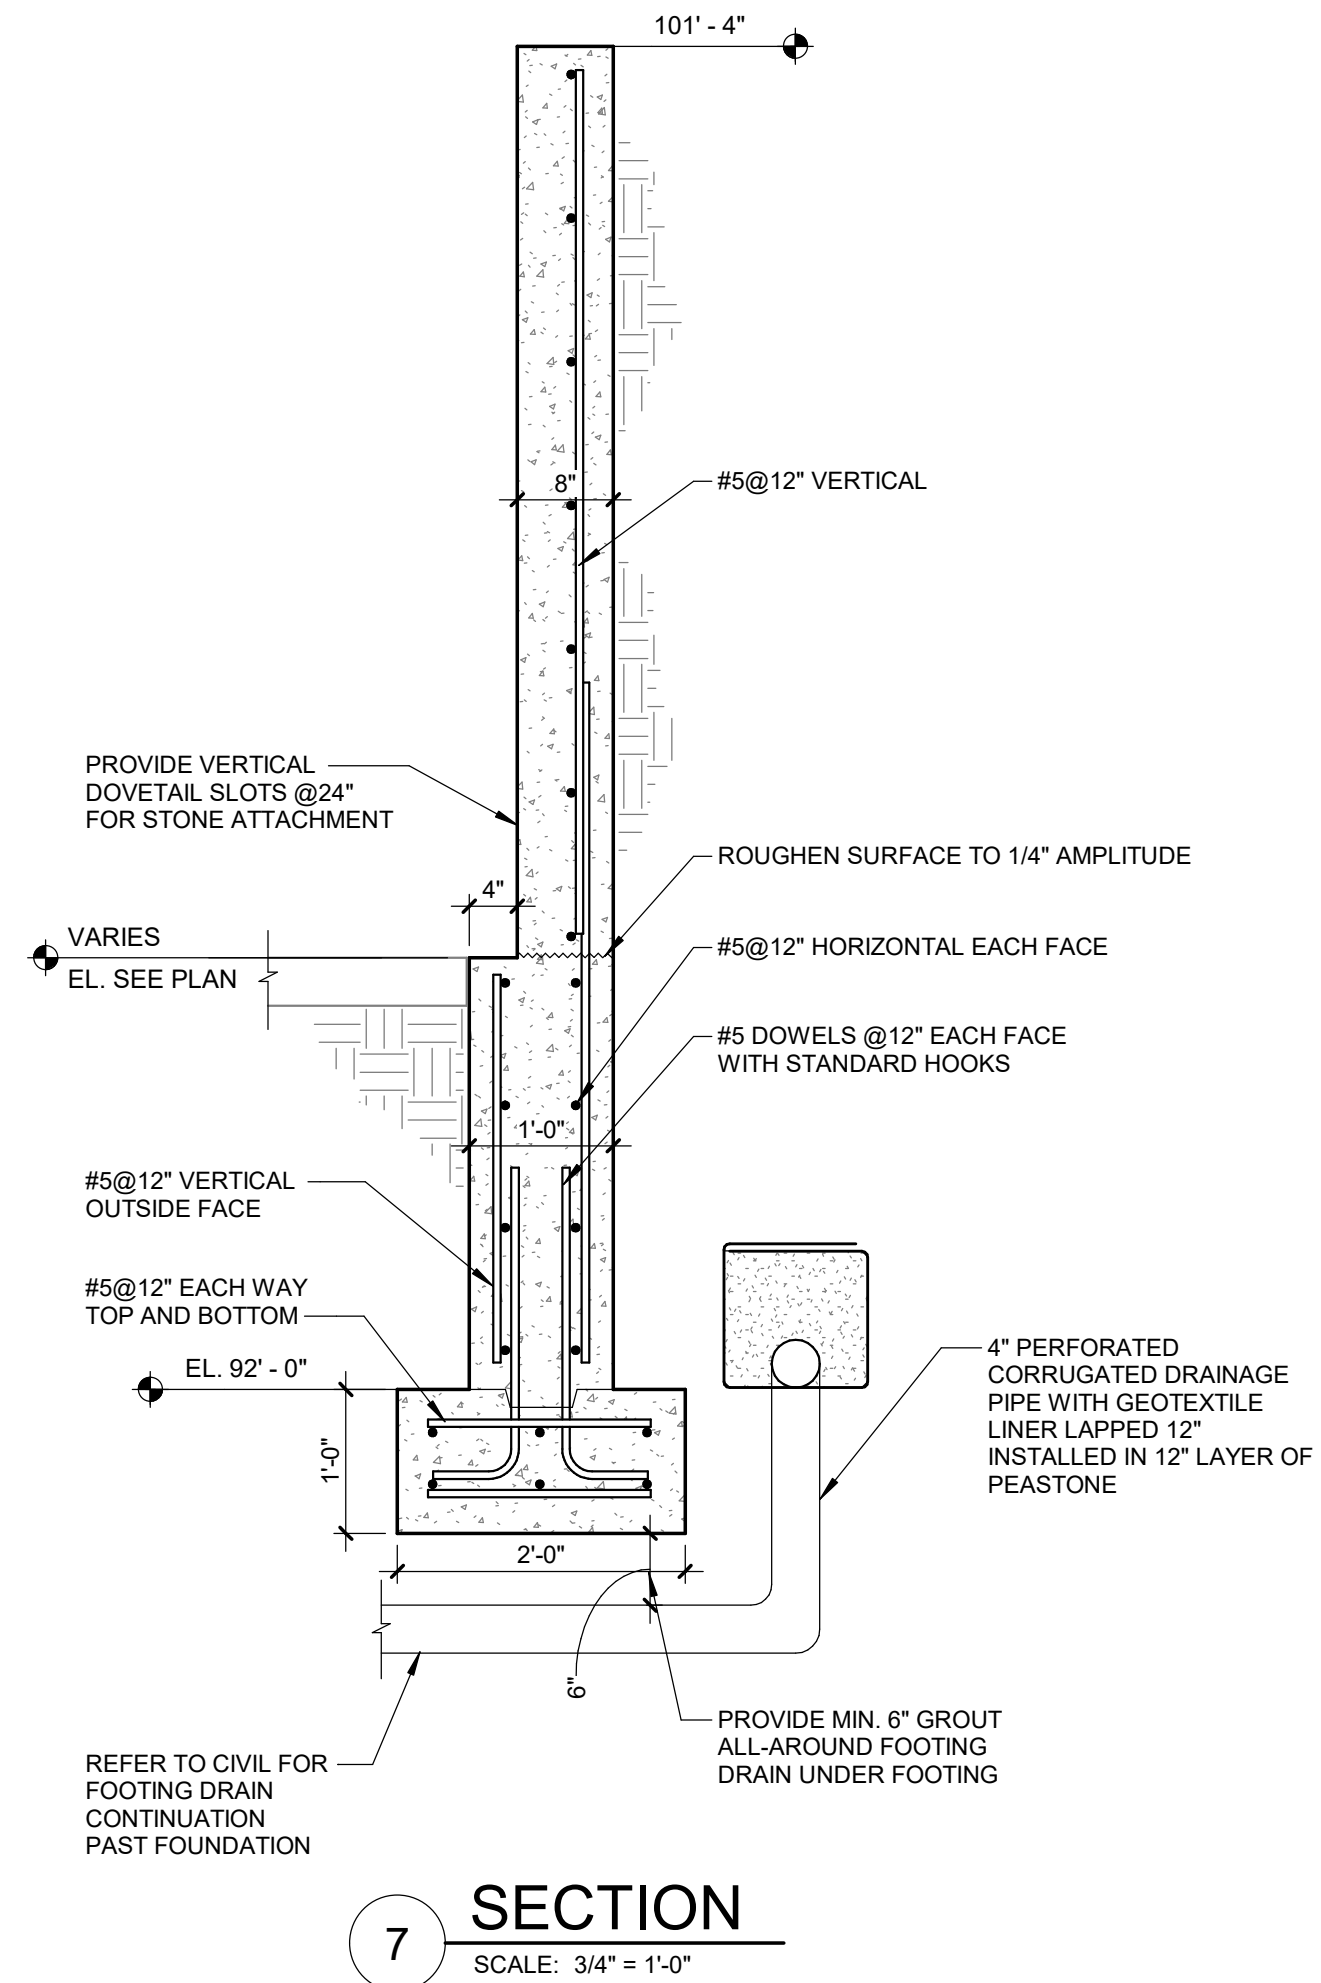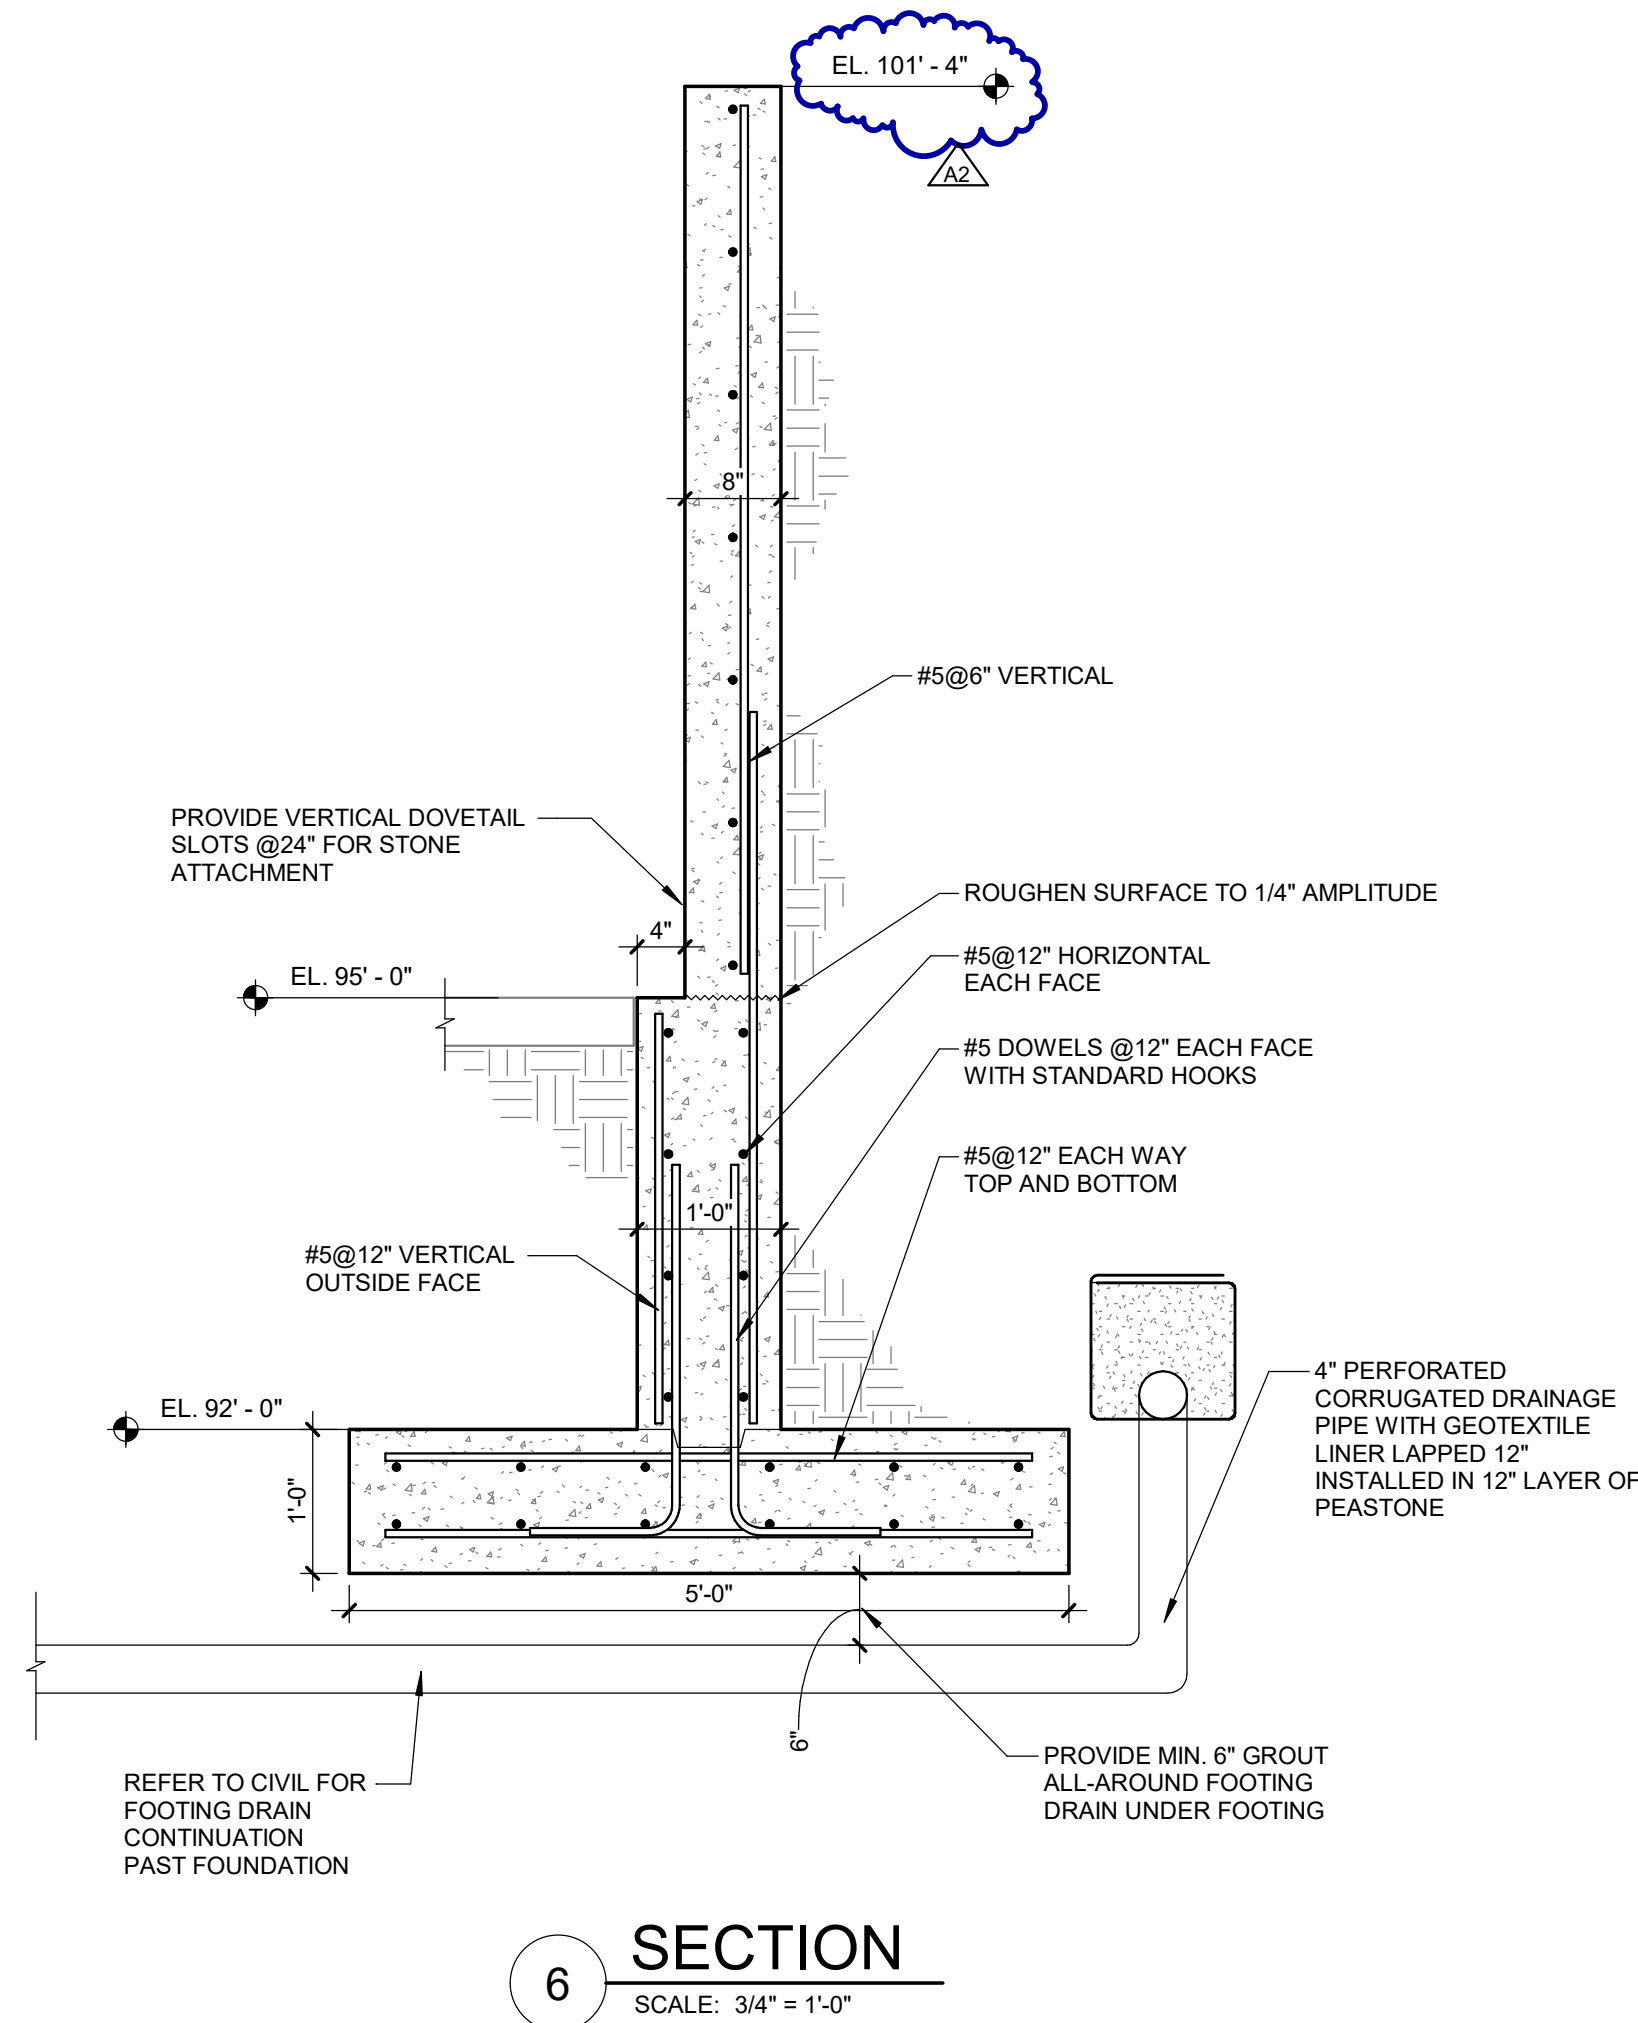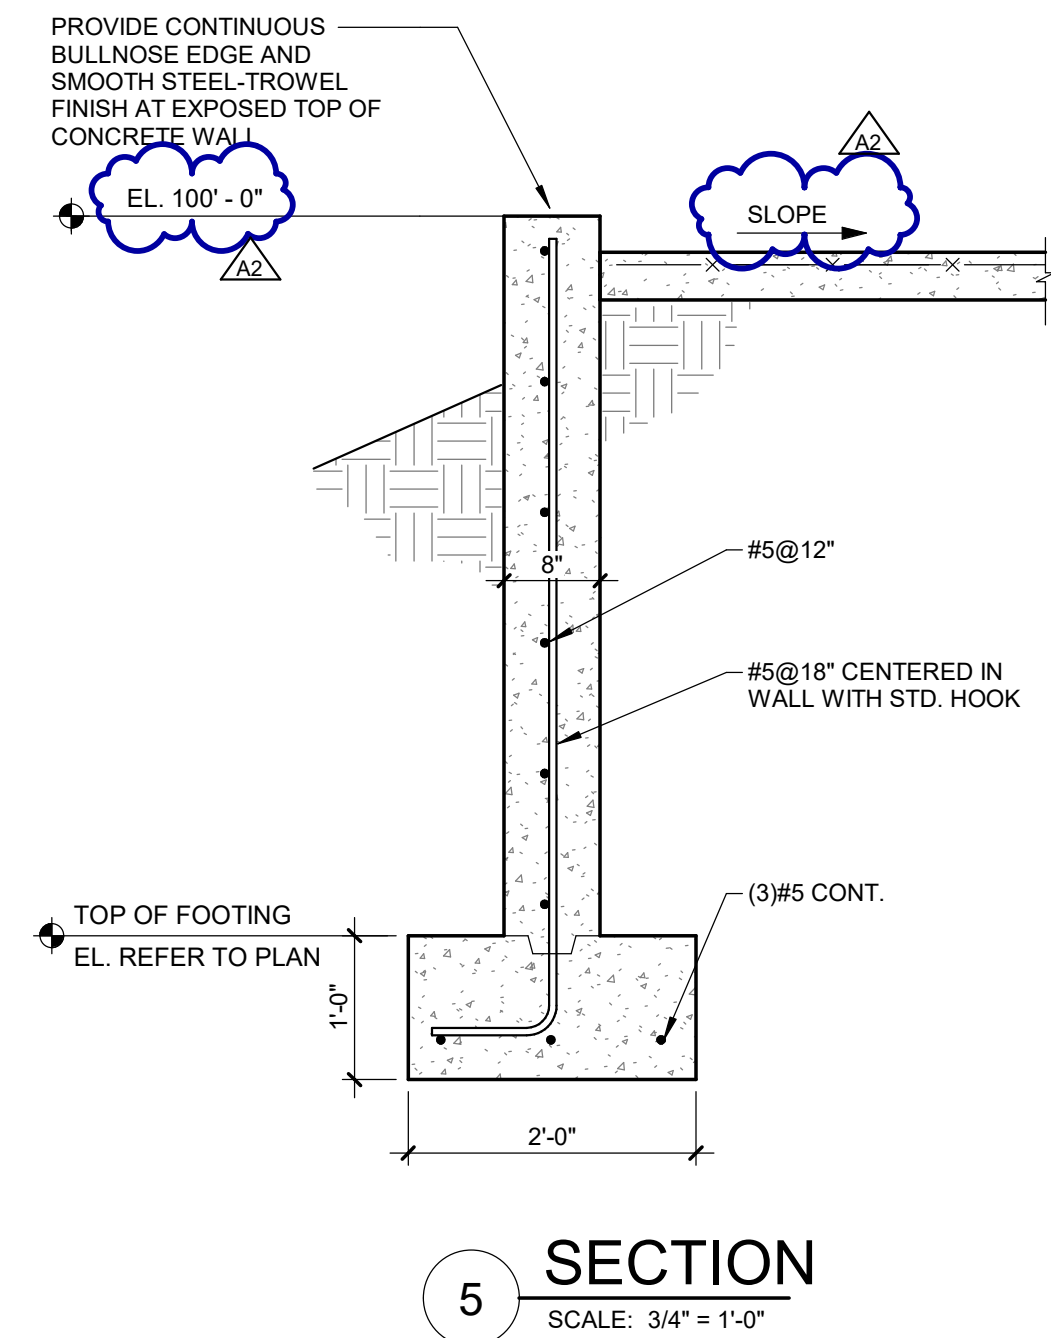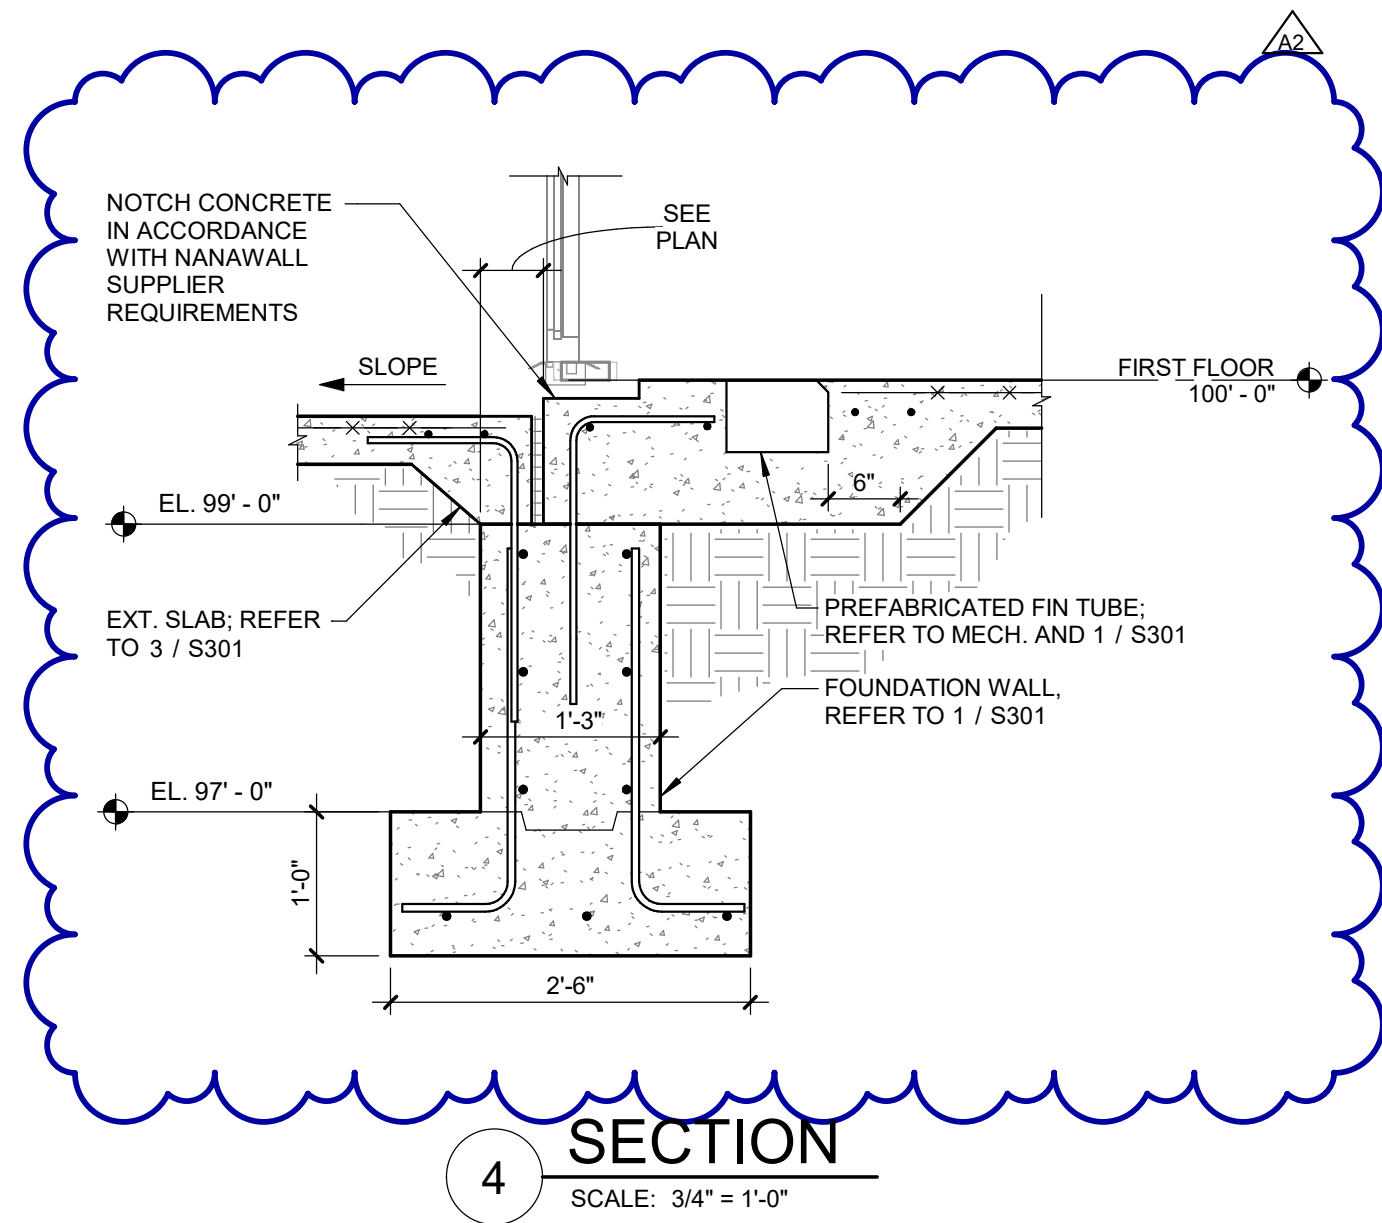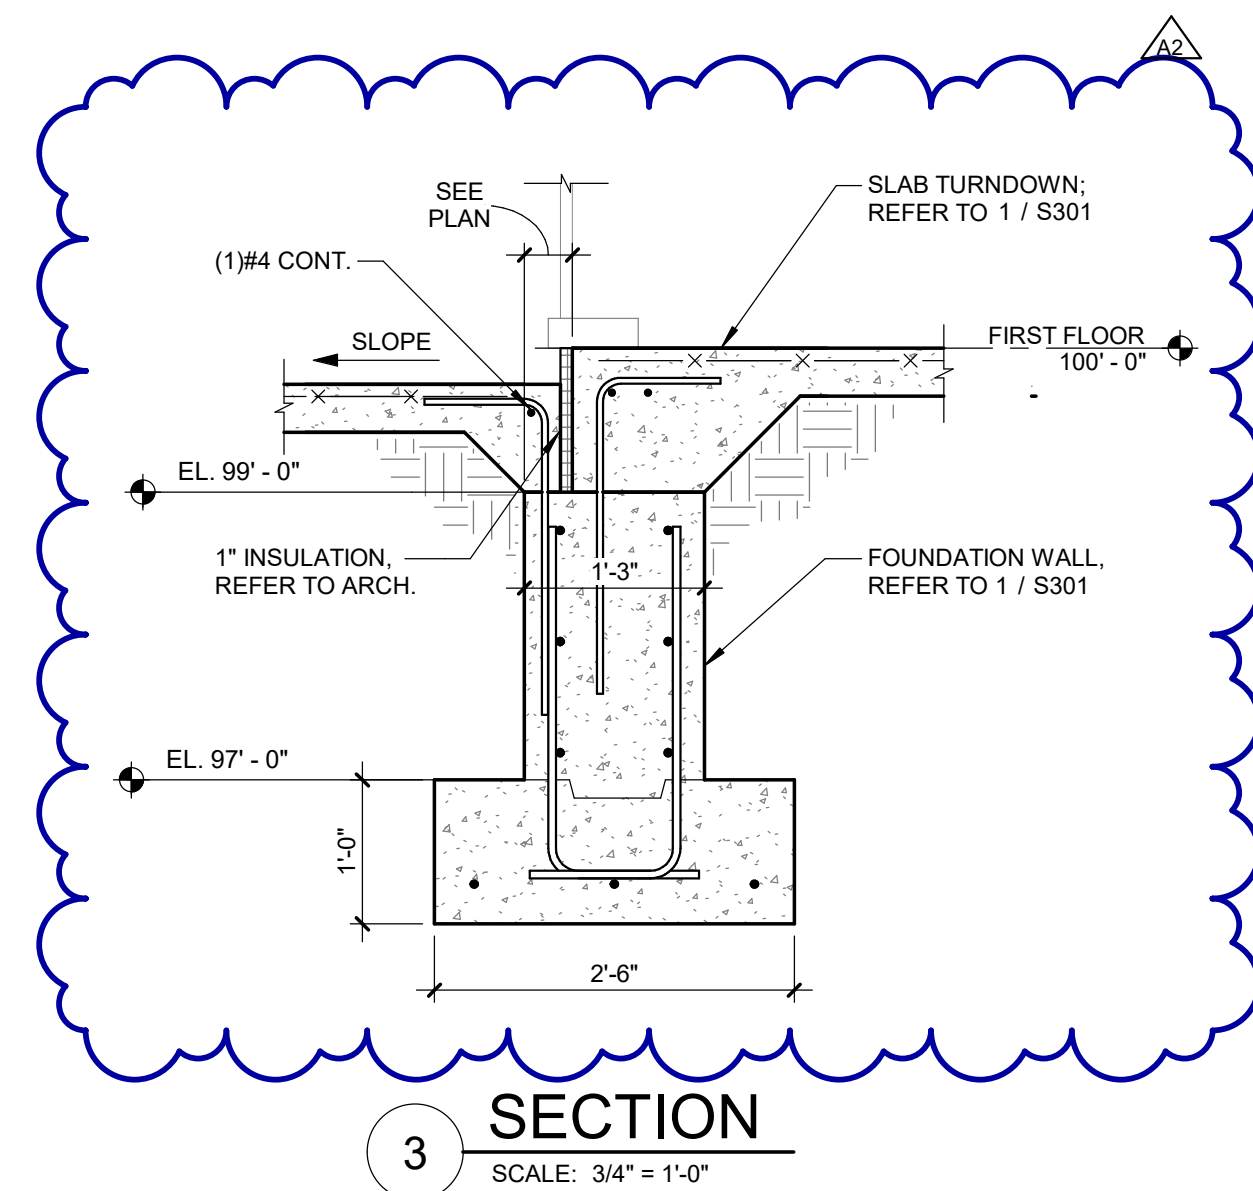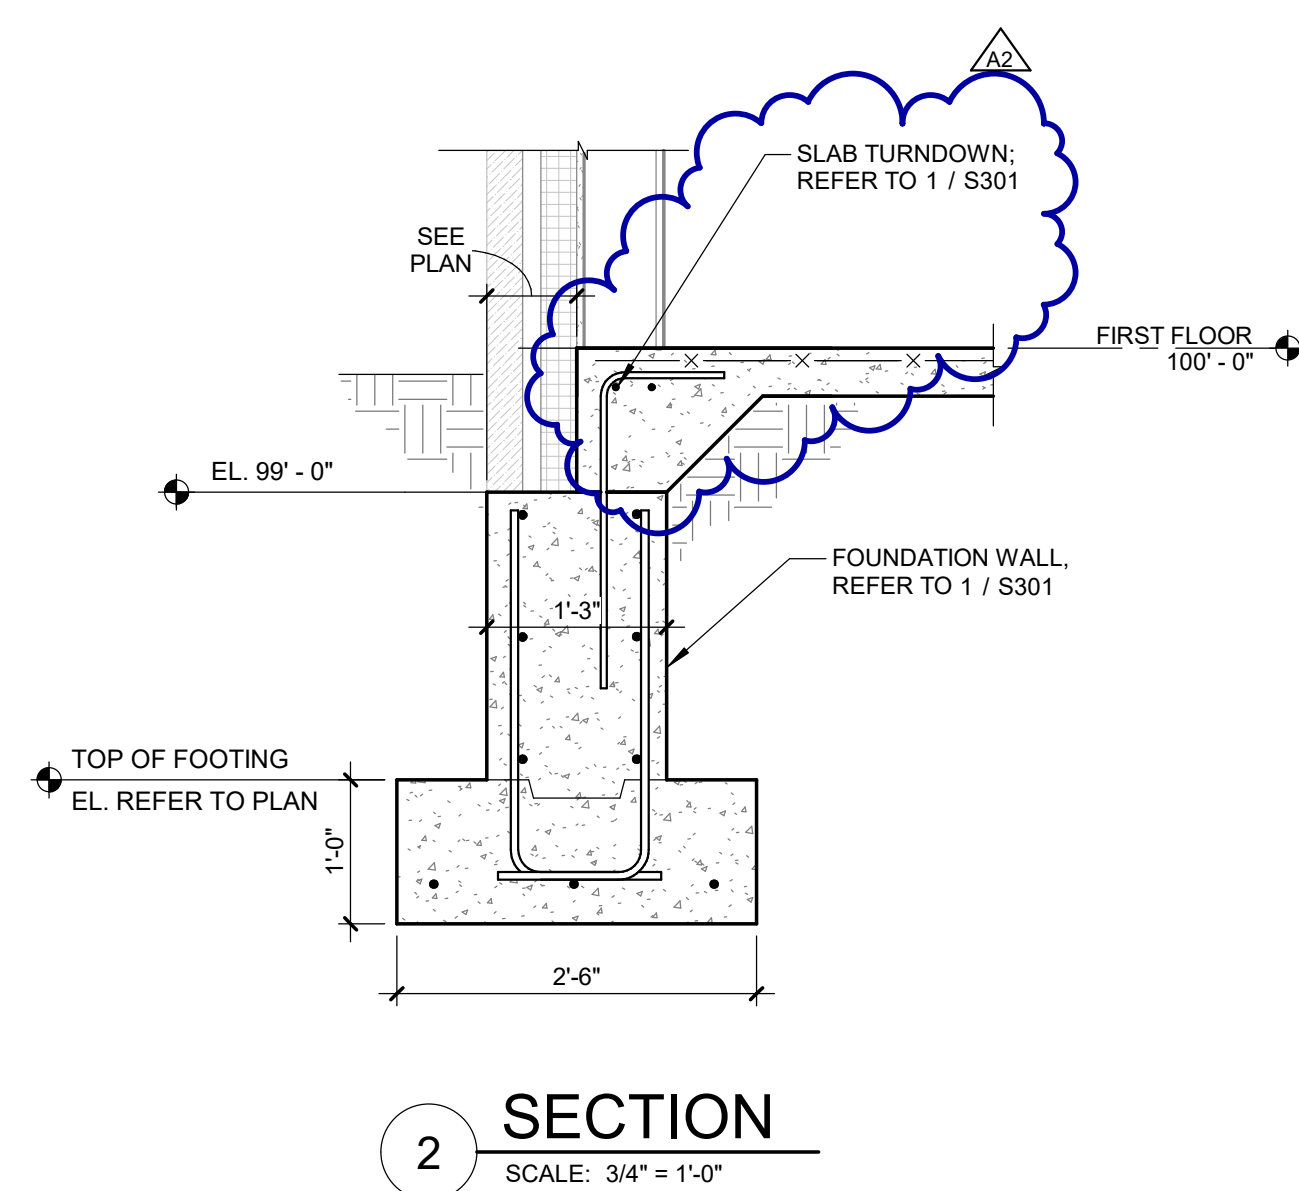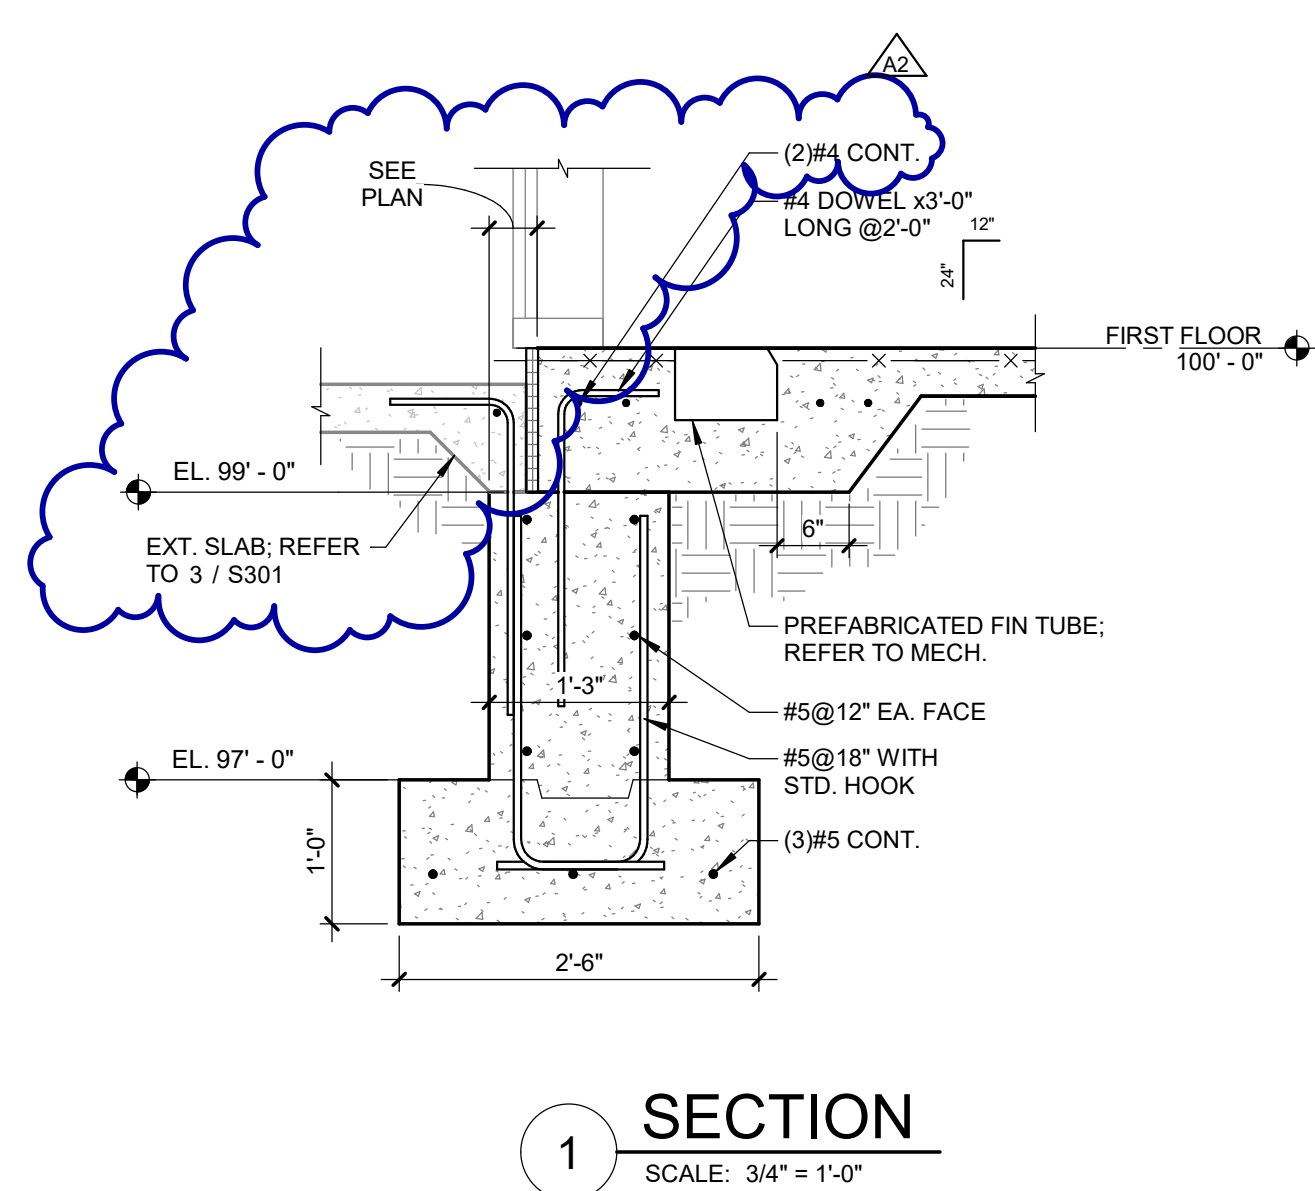

Van Buren Charter Township

Van Buren Township, MI

The Lakeside Park

REVISIONS		
10/27/2022	A2	ADDENDUM NO. 2

10/12/2026	BIDS & PERMIT
09/21/2026	CD PEER REVIEW
09/09/2026	CD TEAM REVIEW
08/10/2026	CD 50% PROGRESS
08/22/2026	DD OWNER REVIEW
06/15/2026	DD PEER REVIEW
06/08/2026	DD 90% PROGRESS
05/18/2026	DD 90% PROGRESS
02/23/2026	SD OWNER REVIEW
02/13/2026	SD PEER REVIEW
02/09/2026	SD PROGRESS REVIEW

Drawn By RMEISSNER
Designer JCARTER
Reviewer CJOTTE
Manager CKRETOVIC

Hard copy is intended to be 24"x36" when plotted. Scale(s) indicated and graphic quality may not be accurate for any other size.

PROJECT NO.
2500281

SHEET NO.

S301

Van Buren Township, MI

The Lakeside Park

REVISIONS		
10/27/2022	A2	ADDENDUM NO. 2

10/12/2026	BIDS & PERMIT
09/21/2026	CD PEER REVIEW
09/09/2026	CD TEAM REVIEW
08/10/2026	CD 50% PROGRESS
06/22/2026	DD OWNER REVIEW
06/15/2026	DD PEER REVIEW
06/08/2026	DD 90 % PROGRESS
05/18/2026	DD 50 % PROGRESS
02/23/2026	SD OWNER REVIEW
02/13/2026	SD PEER REVIEW
02/09/2026	SD PROGRESS REVIEW

Drawn By	RMEISSNER
Designer	JCARTER
Reviewer	CJOTTE
Manager	CKRETOVIC

Hard copy is intended to be 24"x36" when plotted. Scale(s) indicated and graphic quality may not be accurate for any other size.




PROJECT NO.
2500281

SHEET NO. _____

S401

©Copyright 2026
All Rights Reserved



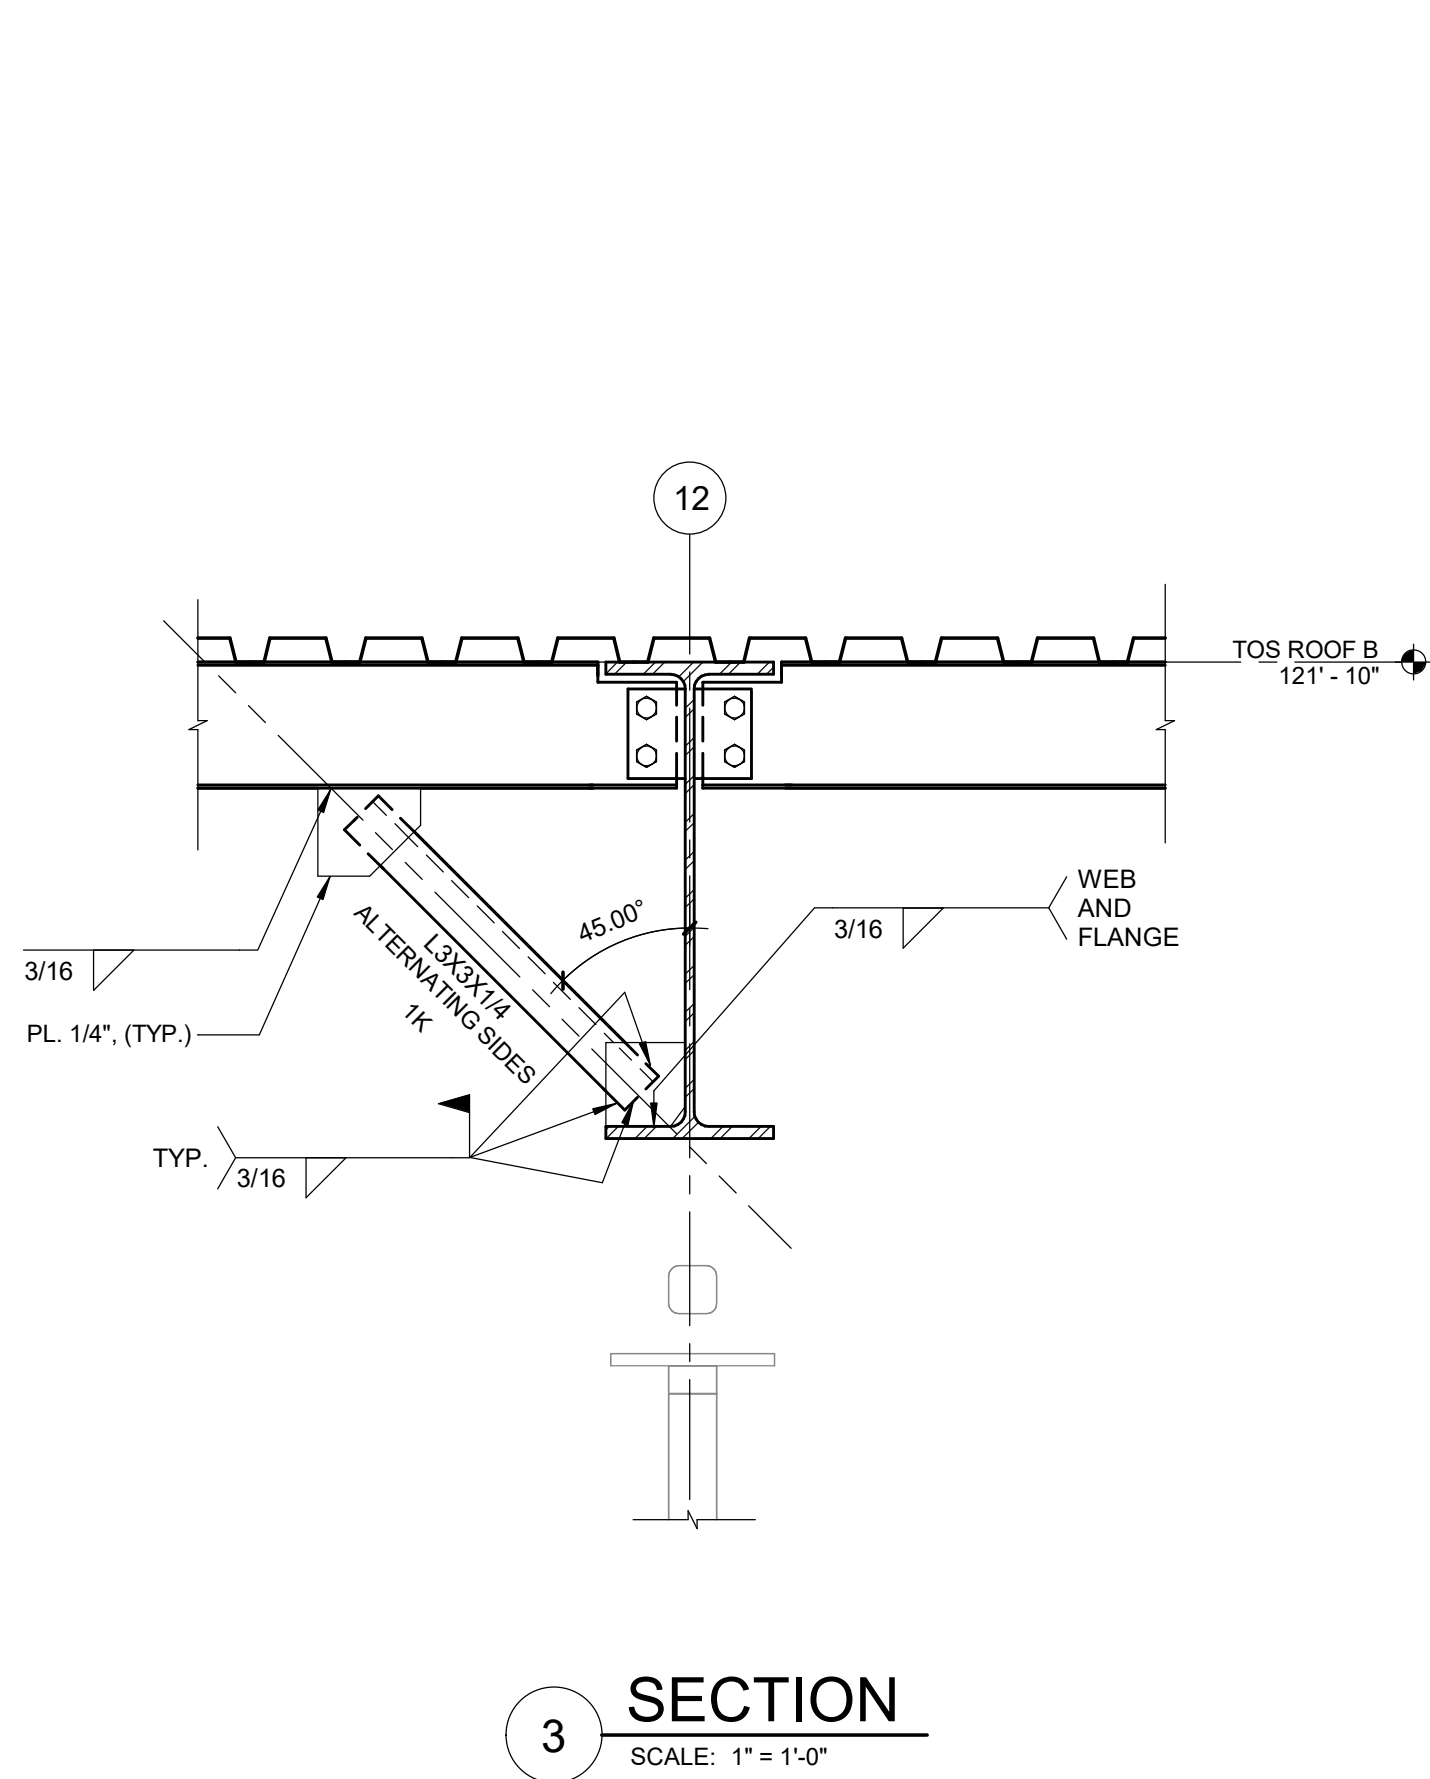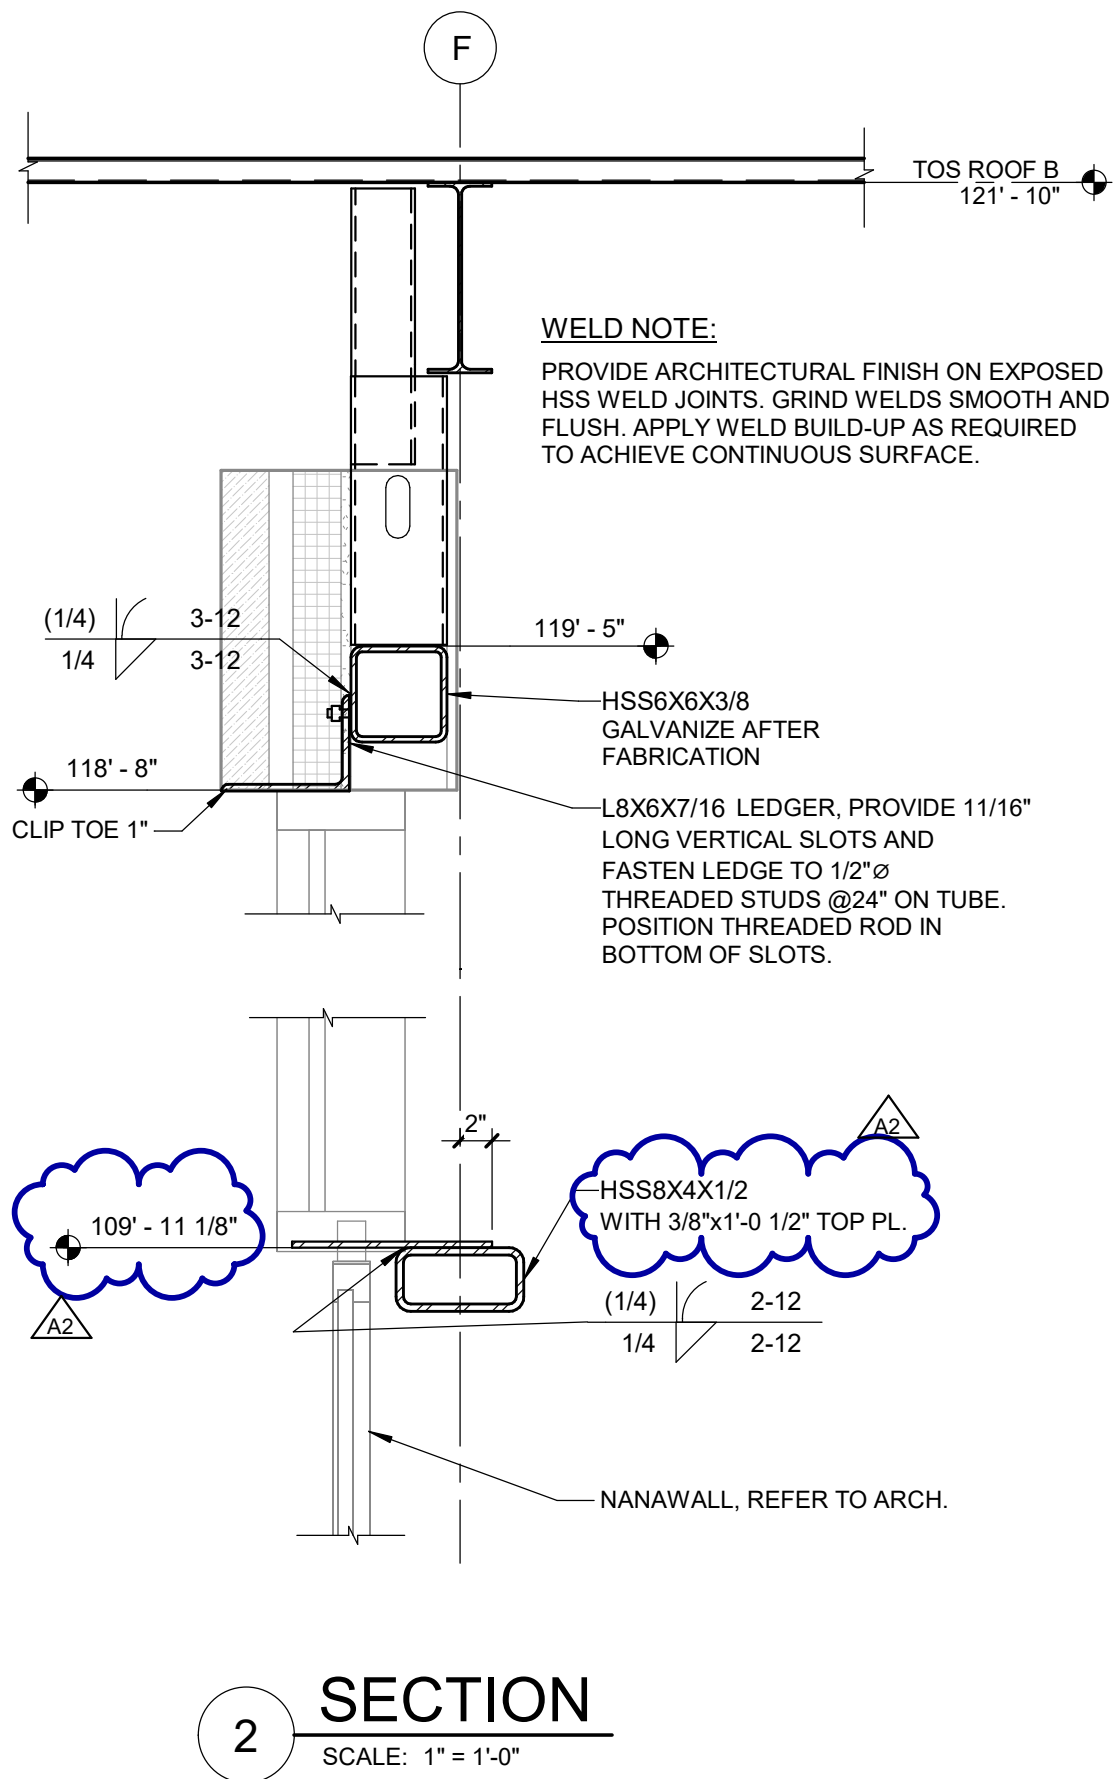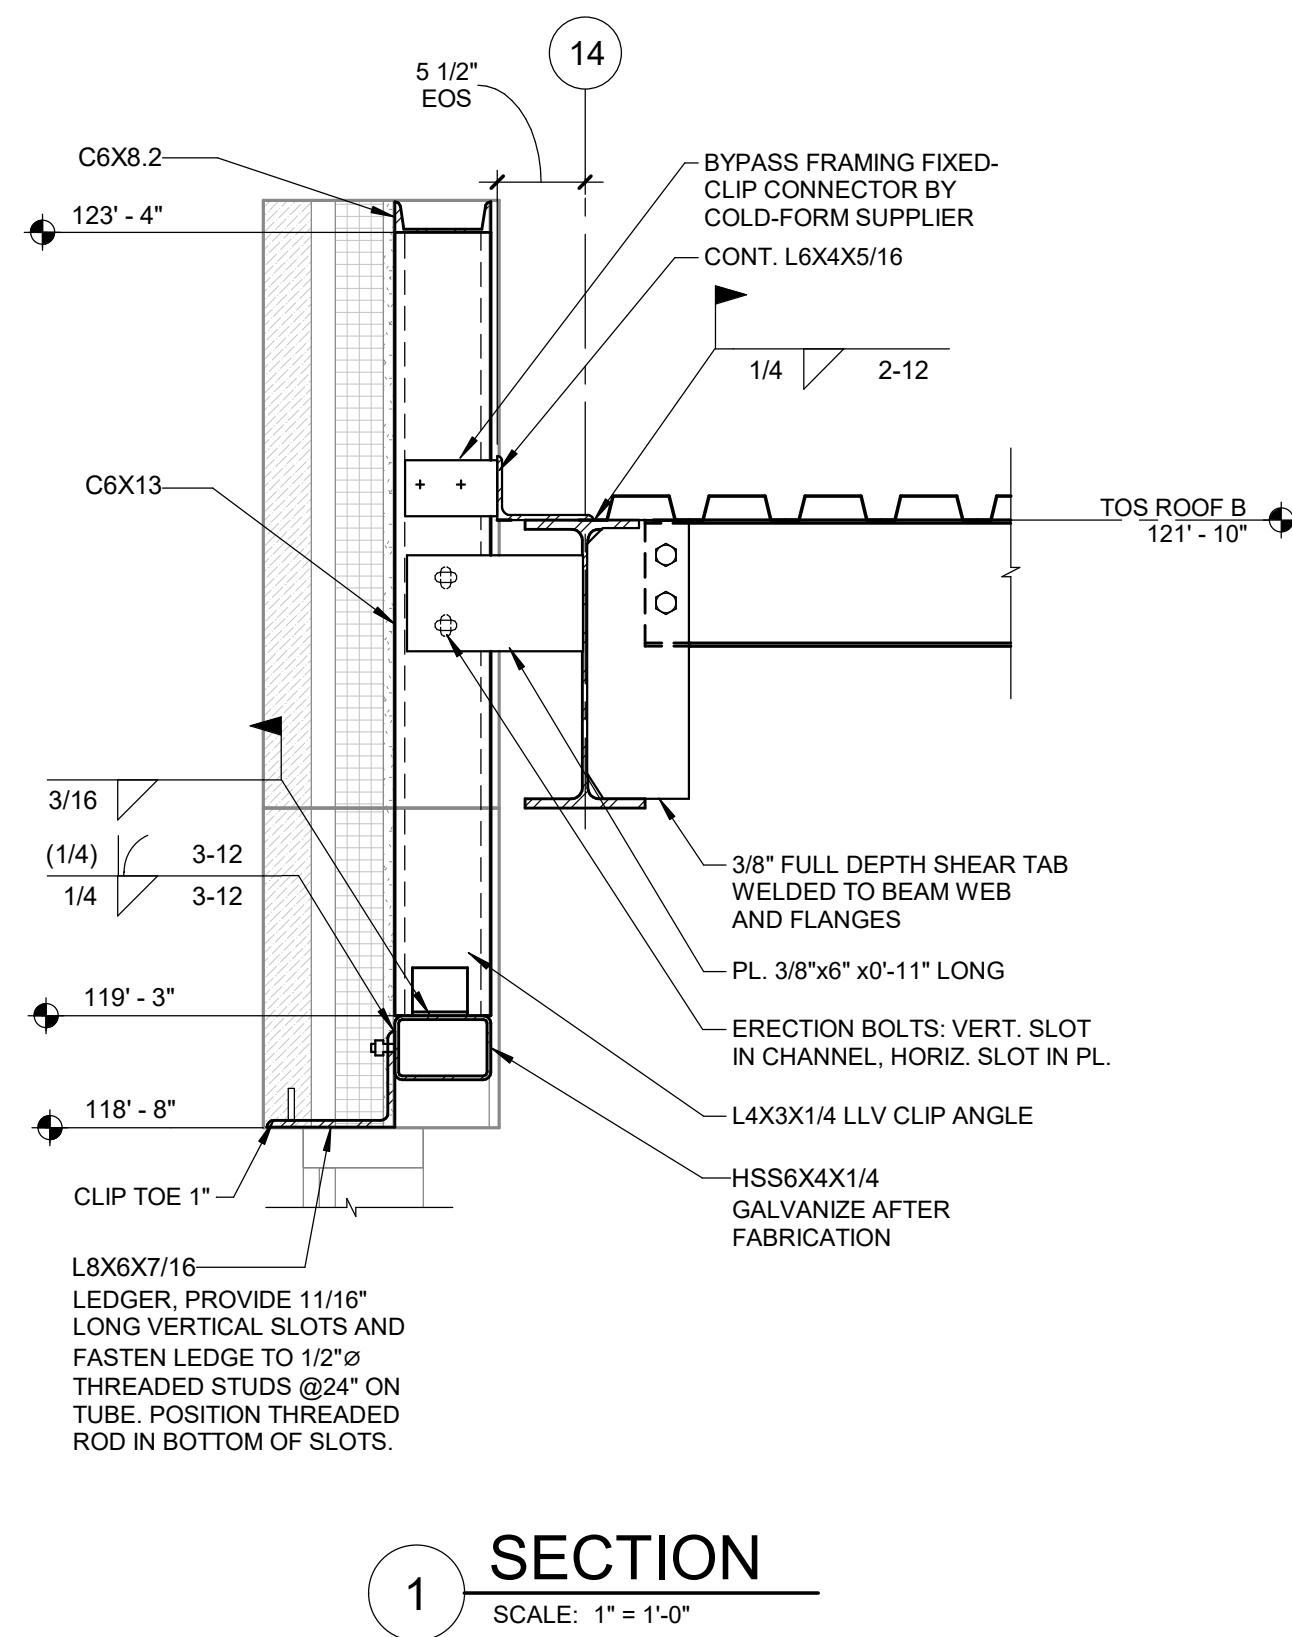

Van Buren Charter Township

Van Buren Township, MI

The Lakeside Park

REVISIONS		
10/27/2022	A2	ADDENDUM NO. 2

10/12/2026	BIDS & PERMIT
09/21/2026	CD PEER REVIEW
09/09/2026	CD TEAM REVIEW
08/10/2026	CD 50% PROGRESS
08/22/2026	DD OWNER REVIEW
06/15/2026	DD PEER REVIEW
06/08/2026	DD 90 % PROGRESS
05/18/2026	DD 90 % PROGRESS
02/23/2026	SD OWNER REVIEW
02/13/2026	SD PEER REVIEW
02/09/2026	SD PROGRESS REVIEW


Drawn By	RMEISSNER
Designer	JCARTER
Reviewer	CJOTTE
Manager	CKRETOVIC

Hard copy is intended to be 24"x36" when plotted. Scale(s) indicated and graphic quality may not be accurate for any other size.

PROJECT NO.
2500281

SHEET NO.


S402

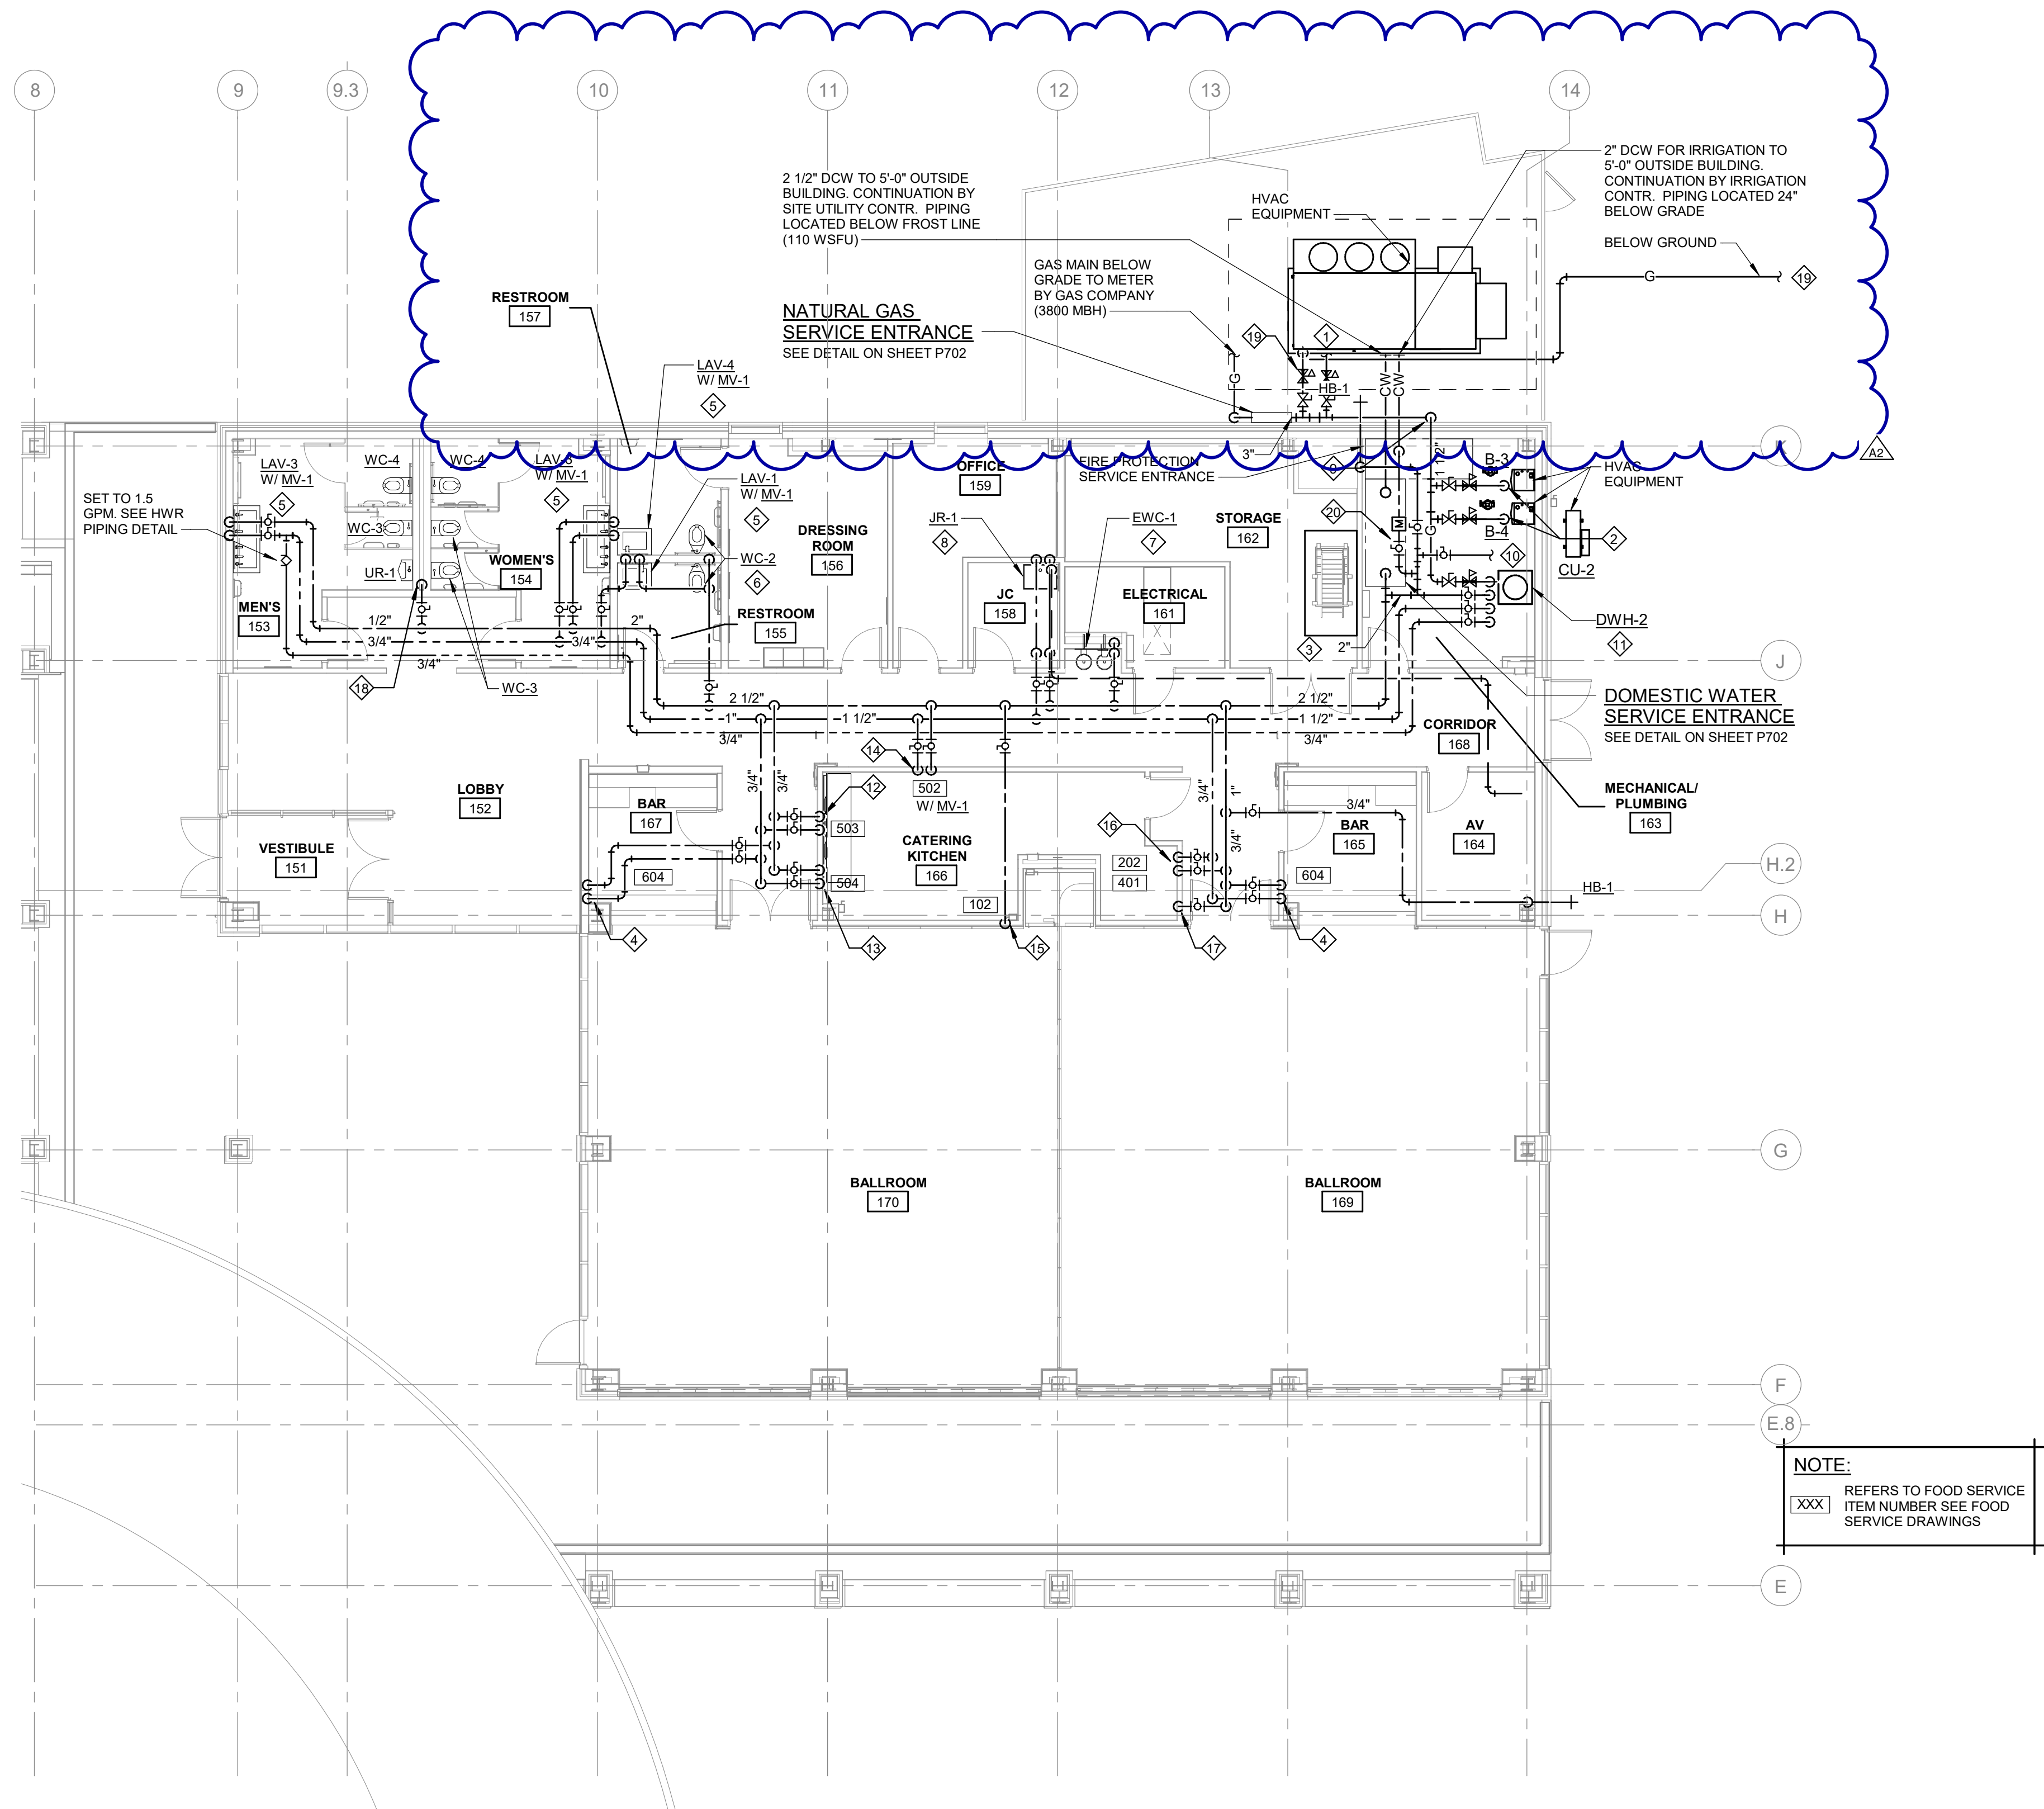

- KEY NOTES**
- 1 1/2" GAS PIPING WITH SHUT-OFF VALVE AND REGULATOR TO ROOFTOP UNIT. PROVIDE WITH 6" DIRT LEG AT CONNECTION.
 - 1 1/4" GAS PIPING WITH SHUT-OFF VALVE AND REGULATOR TO BOILER. PROVIDE WITH 6" DIRT LEG AT CONNECTION.
 - NO PIPING TO BE INSTALLED IN THIS AREA. MAINTAIN CLEARANCE FOR LADDER ACCESS TO ROOF HATCH.
 - 1/2" CW AND HW DOWN IN WALL TO BAR SINK.
 - 1/2" CW AND HW DOWN IN WALL TO MIXING VALVE. CONTINUE 1/2" CW AND 1/2" TW TO LAVATORY.
 - 1 1/2" CW DOWN IN WALL TO WATER CLOSETS. ROUTE 1 1/4" CW TO EACH WC. PROVIDE WITH WATER HAMMER ARRESTOR. SEE SCHEDULE ON SHEET P602.
 - 1/2" CW DOWN IN WALL TO ELECTRIC WATER COOLER.
 - 1/2" CW AND HW DOWN IN WALL TO JANITORS RECEPTOR.
 - GAS PIPING UP ALONG WALL AND ROUTE THRU WALL ABOVE THE CEILING OF THE INTERIOR SPACE.
 - 3/4" HVAC MAKE-UP WATER CONNECTION WITH BACKFLOW PREVENTER AND PRESSURE REGULATOR. ROUTE FULL SIZE DRAIN TO INDIRECT INTO NEAREST F.D. SEE DETAIL ON SHEET P702 FOR MORE INFORMATION.
 - WATER HEATER COMBUSTION AIR AND VENT PIPING UP THRU ROOF. COORDINATE LOCATION WITH HVAC INTAKES TO MAINTAIN MINIMUM 10 FT SEPARATION.
 - 1/2" CW AND HW DOWN IN WALL TO POT SINK.
 - 3/4" HW DOWN IN WALL TO DISHWASHER. PROVIDE SHUT-OFF VALVE, DUAL CHECK BACKFLOW PREVENTER, AND WATER HAMMER ARRESTOR. 1/2" CW DOWN IN WALL TO DRAIN TEMPERING KIT. PROVIDE SHUT-OFF VALVE, DUAL CHECK BACKFLOW PREVENTER, AND WATER HAMMER ARRESTOR.
 - 1/2" CW AND HW DOWN IN WALL TO MIXING VALVE. CONTINUE 1/2" CW AND 1/2" TW TO HAND SINK.
 - 1/2" CW DOWN IN WALL TO ICE MAKER FILTER. PROVIDE SHUT-OFF VALVE AND DUAL CHECK BACKFLOW PREVENTER. CONTINUE 1/2" CW TO ICE MAKER.
 - 1/2" CW AND HW DOWN IN WALL TO PREP SINK.
 - 1/2" CW DOWN IN WALL TO COFFEE MAKER FILTER. PROVIDE SHUT-OFF VALVE AND DUAL CHECK BACKFLOW PREVENTER. CONTINUE 1/2" CW TO COFFEE MAKER.
 - 2" CW DOWN IN CHASE TO FIXTURES. PROVIDE WITH WATER HAMMER ARRESTOR. SEE SCHEDULE ON SHEET P602.
 - 2 1/2" GAS PIPING WITH SHUT-OFF VALVE AND REGULATOR FOR GENERATOR. ROUTE PIPING BELOW GRADE TO GENERATOR. PROVIDE WITH 6" DIRT LEG AT CONNECTION.
 - 2" IRRIGATION WATER CONNECTION WITH BACKFLOW PREVENTER AND DEDUCT METER. ROUTE FULL SIZE DRAIN TO INDIRECT INTO NEAREST F.D. SEE DETAIL ON SHEET P702 FOR MORE INFORMATION.

NOTE:
xxx REFERS TO FOOD SERVICE
ITEM NUMBER SEE FOOD
SERVICE DRAWINGS

KEY PLAN

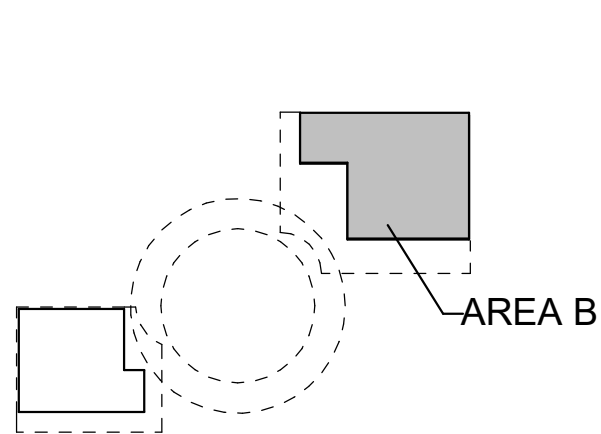

LAKE HALL
FIRST FLOOR PLUMBING SUPPLY PIPING PLAN - AREA B
SCALE: 1/8" = 1'-0"

Van Buren Charter Township

Van Buren Township, MI

The Lakeside Park

REVISIONS		
10/27/2022	A2	ADDENDUM NO. 2

10/12/2026	BIDS & PERMIT
09/21/2026	CD PEER REVIEW
09/09/2026	CD TEAM REVIEW
08/10/2026	CD 50% PROGRESS
08/22/2026	DD OWNER REVIEW
06/15/2026	DD PEER REVIEW
06/08/2026	DD 90 % PROGRESS
05/18/2026	DD 90 % PROGRESS
02/23/2026	SD OWNER REVIEW
02/13/2026	SD PEER REVIEW
02/09/2026	SD PROGRESS REVIEW


Drawn By	JBFTZSIMMONS
Designer	JBFTZSIMMONS
Reviewer	GLOUIS
Manager	CKRETOVIC

Hard copy is intended to be
24"x36" when plotted. Scale(s)
indicated and graphic quality may
not be accurate for any other size.

PROJECT NO.	2500281
SHEET NO.	

P302

PLOT INFO: 10/27/2026 9:28:30 AM Autodesk Docs://2500281 - Van Buren Twp Lake House/2026_M_2500281.rvt

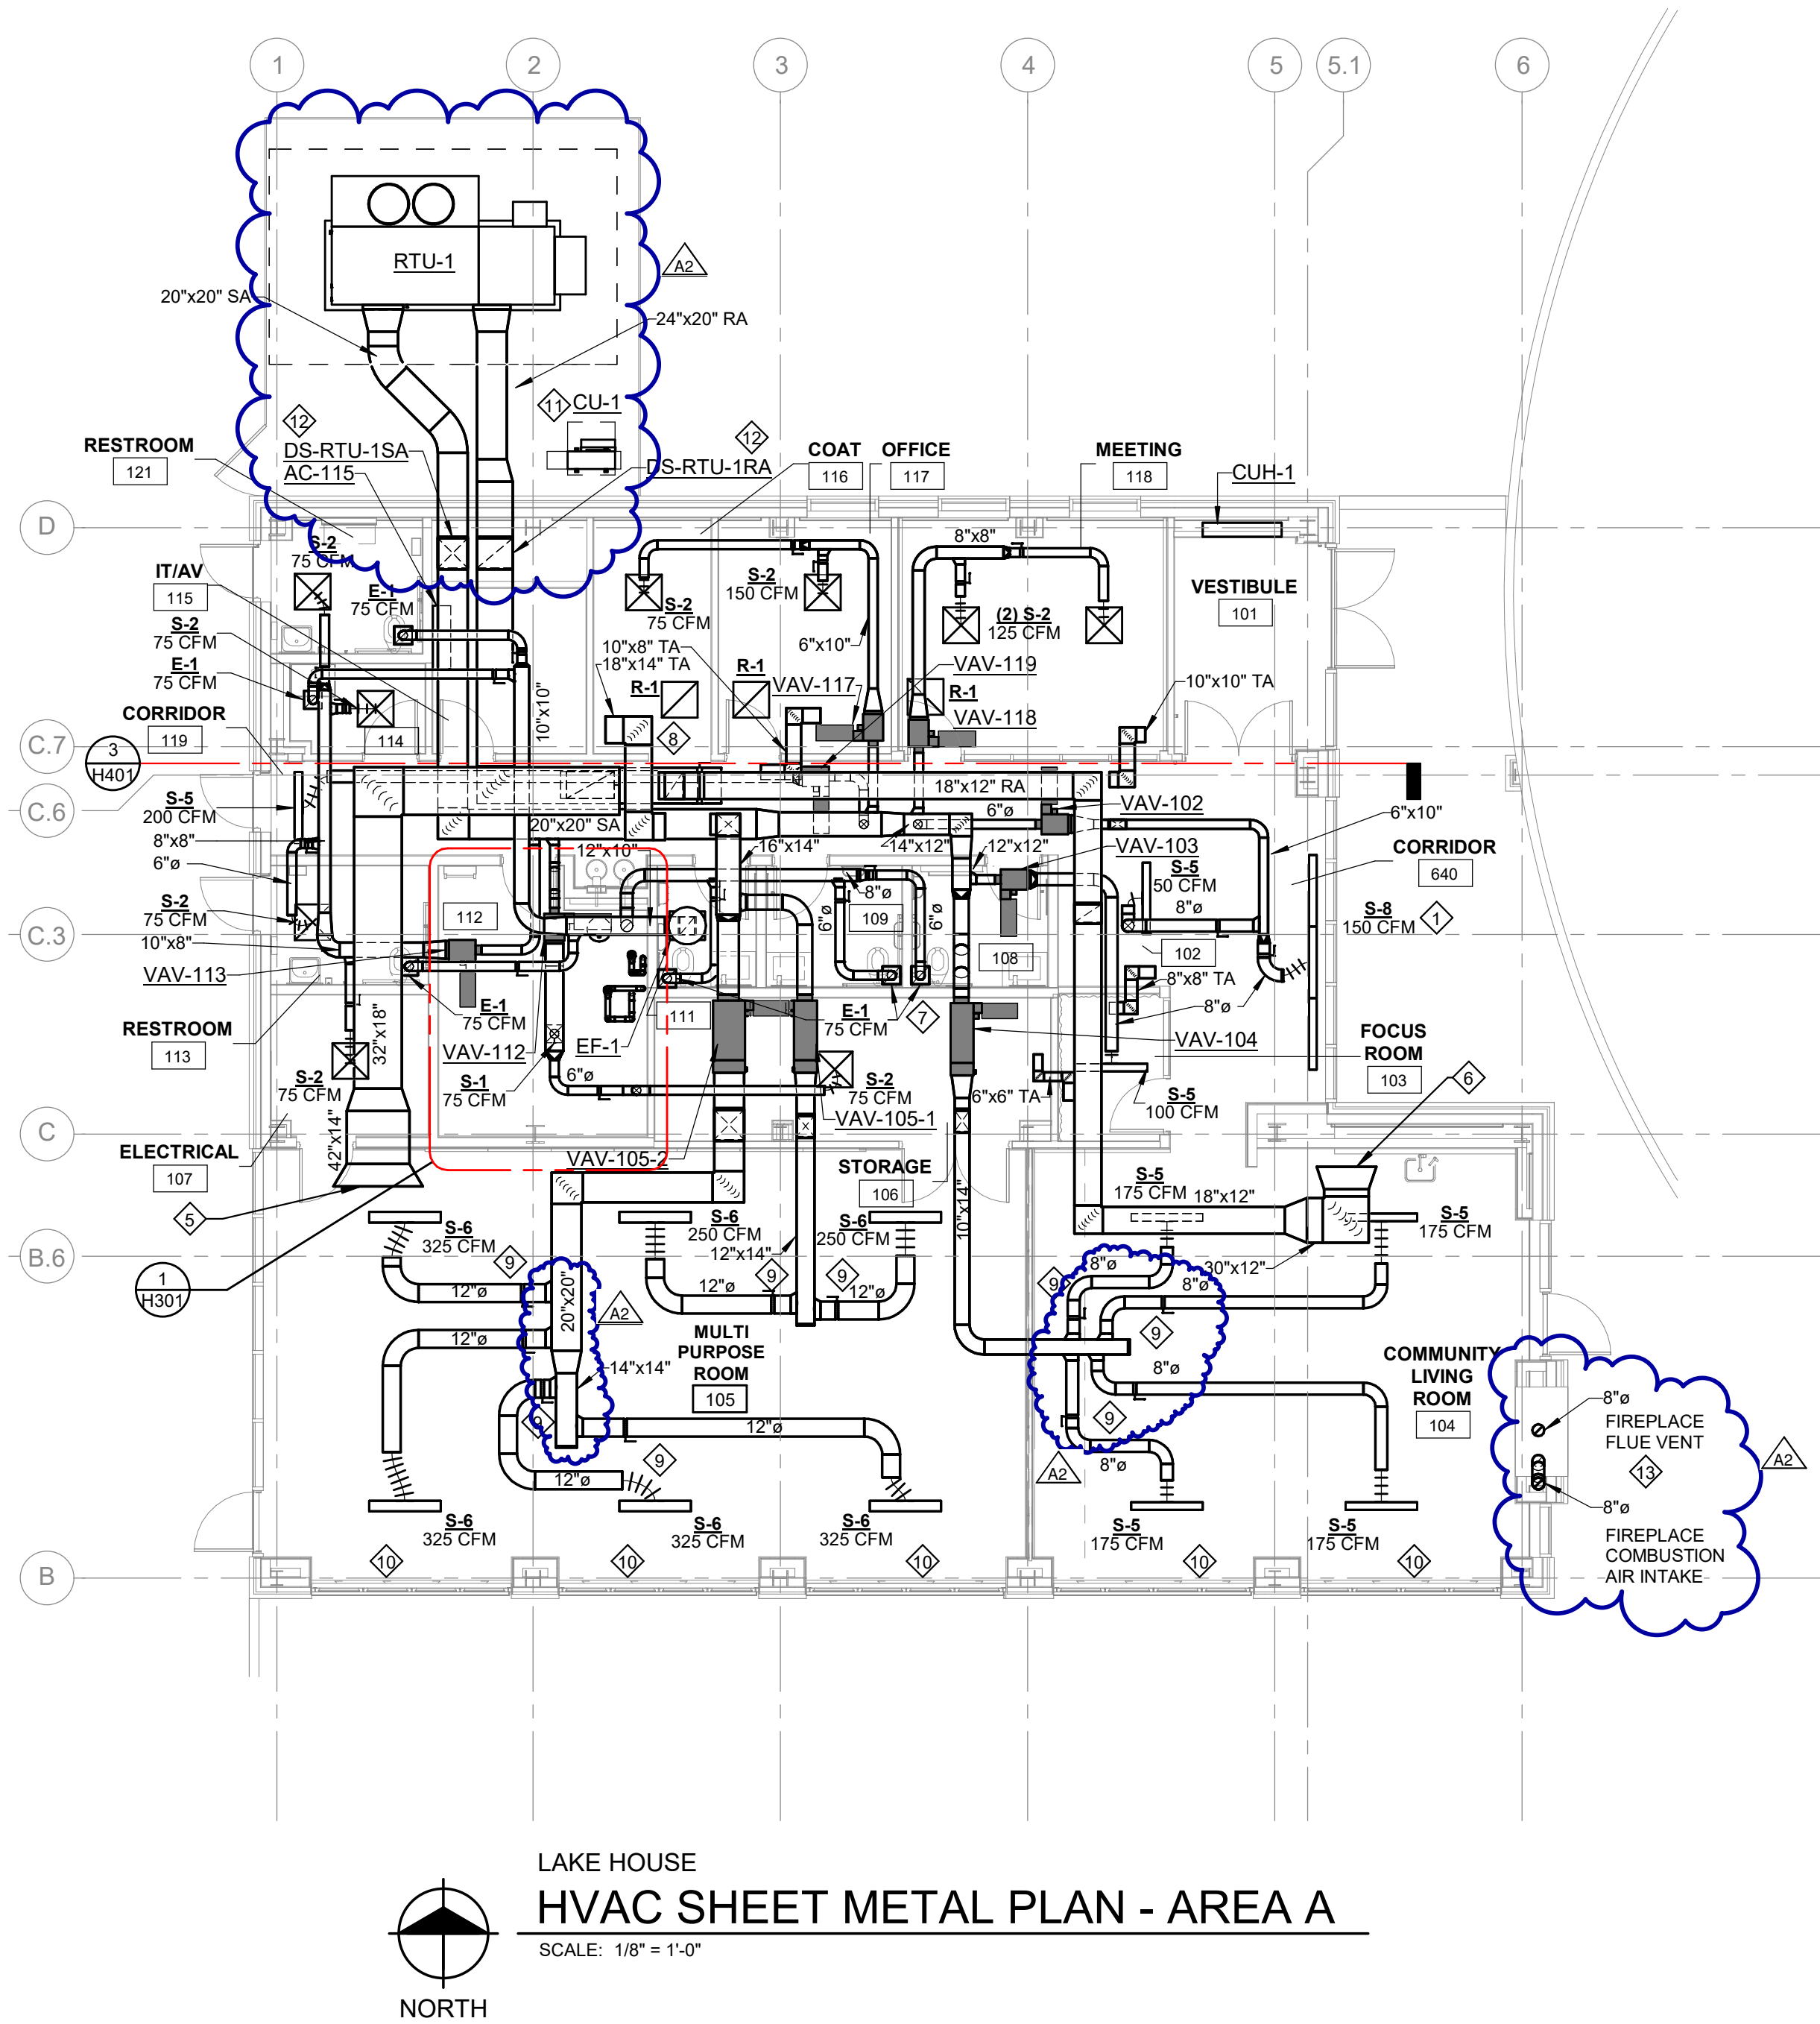


NOTES


1. DUCT BRANCHES TO DIFFUSERS/GRILLES SHALL BE FULL SIZE OF DIFFUSER/GRILLE NECK UNLESS NOTED OTHERWISE.
2. DUCT BRANCHES TO TERMINAL UNITS SHALL BE FULL SIZE OF TERMINAL UNIT INLET CONNECTION UNLESS NOTED OTHERWISE.

KEY NOTES

1. PROVIDE 12 FT CONTINUOUS DIFFUSER, CENTER 4 FT IS A ACTIVE DIFFUSER.
2. BALANCE RETURN DAMPER TO 1400 CFM.
3. BALANCE RETURN DAMPER TO 700 CFM.
4. BALANCE RETURN DAMPER TO 1800 CFM.
5. PROVIDE A 60" x 20" OPEN ENDED RETURN AIR DUCT. RETURN AIR SHALL BE TRANSFERRED FROM THE SPACE THROUGH THE PLENUM CAVITY FORMED BEHIND THE ACOUSTICAL PANEL ON THE NORTH WALL AND ROUTED ABOVE THE CEILING TO THE RETURN AIR DUCT.
6. PROVIDE A 40" x 12" OPEN-ENDED RETURN AIR DUCT. RETURN AIR SHALL BE TRANSFERRED FROM THE SPACE THROUGH THE OPENING LOCATED ABOVE THE UPPER CABINETS AND ROUTED TO THE RETURN AIR DUCT ABOVE THE CEILING.
7. PROVIDE YOUNG REGULATOR COMPANY 270-275 WITH 5020CC DAMPER FOR REMOTE DAMPER CONTROL OF EXHAUST GRILLES.
8. TRANSFERS RETURN AIR FROM COAT 116, CORRIDOR 119, CORRIDOR 640, AND RECEPTION 102 INTO THE RETURN PLENUM.
9. DAMPER MUST BE MOUNTED AT LEAST 10 DUCT DIAMETERS FROM THE DIFFUSER AS DIRECTED BY THE ACOUSTICAL CONSULTANT DUE TO NOISE CONCERNS.
10. THE CONTROLS CONTRACTOR SHALL PROVIDE ALL REQUIRED WIRINGS FROM THE REED DOOR CONTACT FURNISHED BY THE DOOR MANUFACTURER AND SHALL INTERFACE THE DOOR CONTACT WITH THE ASSOCIATED VAV TERMINAL UNIT SERVING THE SPACE. THE DOOR CONTACT STATUS SHALL BE MONITORED AND UTILIZED FOR CONTROL FUNCTIONS AS SPECIFIED.
11. PROVIDE CURB WITH CONDENSING UNIT.
12. SILENCER IN VERTICAL DUCT.
13. FIREPLACE MANUFACTURER TO PROVIDE VERTICALLY TERMINATED POWER EXHAUST FAN, INTERLOCK THROUGH FIREPLACE CONTROLS. PROVIDE A MINIMUM OF 24" BETWEEN THE COMBUSTION AIR INTAKE AND THE FLUE VENT.

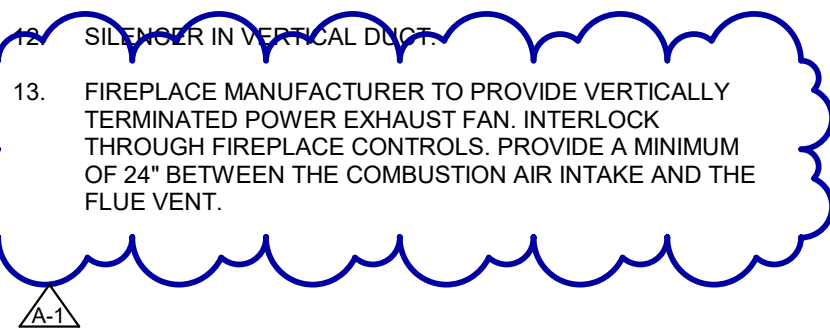

KEY PLAN

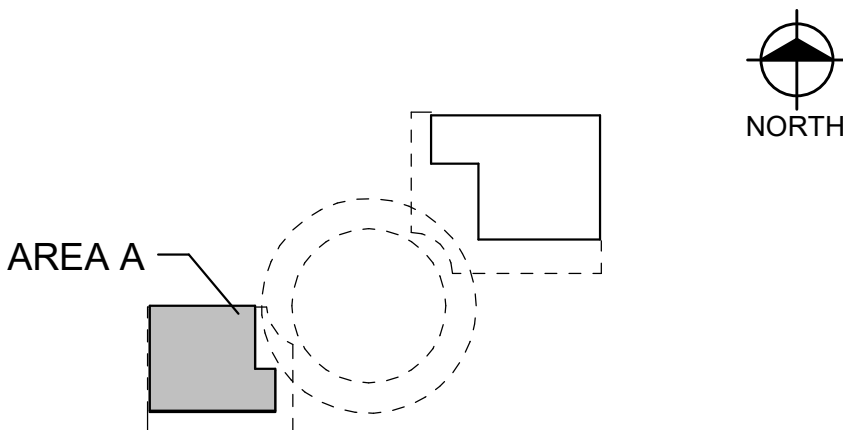

Van Buren Charter Township

Van Buren Township, MI

The Lakeside Park

REVISIONS		
10/27/2022	A2	ADDENDUM NO. 2

10/12/2026	BIDS & PERMIT
09/21/2026	CD PEER REVIEW
09/09/2026	CD TEAM REVIEW
08/10/2026	CD 50% PROGRESS
08/22/2026	DD OWNER REVIEW
06/15/2026	DD PEER REVIEW
06/08/2026	DD 90 % PROGRESS
05/18/2026	DD 50 % PROGRESS
02/23/2026	SD OWNER REVIEW
02/13/2026	SD PEER REVIEW
02/09/2026	SD PROGRESS REVIEW

Drawn By	CUHLIG
Designer	CUHLIG
Reviewer	GLOUIS
Manager	CKRETOVIC

Hard copy is intended to be 24"x36" when plotted. Scale(s) indicated and graphic quality may not be accurate for any other size.

PROJECT NO.	2500281
SHEET NO.	

H101

©Copyright 2026
All Rights Reserved

Van Buren Township, MI

The Lakeside Park

10/27/2022	A2	ADDENDUM NO. 2
------------	----	----------------

Drawn By	CUHLIG
Designer	CUHLIG
Reviewer	GLOUIS
Manager	CKRETOVIC

PROJECT NO.
2500281

SHEET NO.

©Copyright 2026
All Rights Reserved

1. DUCT BRANCHES TO DIFFUSERS/GRILLES SHALL BE FULL SIZE OF DIFFUSER/GRILLE NECK UNLESS NOTED OTHERWISE.
2. DUCT BRANCHES TO TERMINAL UNITS SHALL BE FULL SIZE OF TERMINAL UNIT INLET CONNECTION UNLESS NOTED OTHERWISE.
3. REFER TO SECTION 2 ON SHEET H401 FOR DUCT DIMENSIONS IN CORRIDOR.

1. SUPPLY DIFFUSER TO SERVE MEZZANINE ABOVE STORAGE ROOM.
2. COORDINATE VAV BOX LOCATION WITH LIGHTING, DIFFUSERS, SPRINKLERS, AND CEILING TILES TO ENSURE BOXES CAN BE ADEQUATELY ACCESSED.
3. SET RETURN BALANCE DAMPER TO 1500 CFM.
4. SET RETURN BALANCE DAMPER TO 2900 CFM.
5. SET RETURN BALANCE DAMPER TO 2700 CFM.
6. SET RETURN BALANCE DAMPER TO 100 CFM.
7. PROVIDE 8 FT CONTINUOUS DIFFUSER. THE CENTER 4 FT SECTION HAS AIRFLOW, THE OUTER 2 FT ON EACH END ARE BLANK OFF PANELS.
8. PROVIDE 12 FT CONTINUOUS DIFFUSER. CENTER 4 FT IS A BLANK OFF PANEL.
9. BOTTOM CONTROL ACCESS VAV.
10. PROVIDE YOUNG REGULATOR COMPANY 270-275 WITH 5020CC DAMPER FOR REMOTE DAMPER CONTROL.
11. THE CONTROLS CONTRACTOR SHALL PROVIDE ALL REQUIRED WIRING FROM THE REED DOOR CONTACT FURNISHED BY THE DOOR MANUFACTURER AND SHALL INTERFACE THE DOOR CONTACT WITH THE ASSOCIATED VAV TERMINAL UNIT SERVING THE SPACE. THE DOOR CONTACT STATUS SHALL BE MONITORED AND UTILIZED FOR CONTROL FUNCTIONS AS SPECIFIED.
12. PROVIDE CONDENSING UNIT WITH CURB.
13. DAMPER MUST BE MOUNTED AT LEAST 10 DUCT DIAMETERS FROM THE DIFFUSER AS DIRECTED BY THE ACoustICAL CONSULTANT DUE TO NOISE CONCERNS.

NORTH

AREA B



Van Buren Township, MI

The Lakeside Park

10/27/2022	A2	ADDENDUM NO. 2
------------	----	----------------

1. <i>Chrysomelidae</i>	2. <i>Curculionidae</i>	3. <i>Chrysomelidae</i>
-------------------------	-------------------------	-------------------------

10/12/2026	BIDS & PERMIT
09/21/2026	CD PEER REVIEW
09/09/2026	CD TEAM REVIEW
08/10/2026	CD 50% PROGRESS
06/22/2026	DD OWNER REVIEW
06/15/2026	DD PEER REVIEW
06/08/2026	DD 90 % PROGRESS
05/18/2026	DD 50 % PROGRESS
02/23/2026	SD OWNER REVIEW
02/13/2026	SD PEER REVIEW
02/09/2026	SD PROGRESS REVIEW

Manager CKRETOVIC

Hard copy is intended to be 24"x36" when plotted. Scale(s) indicated and graphic quality may not be accurate for any other size.

2500281

SHEET NO.

H201

©Copyright 2026
All Rights Reserved

GENERAL NOTES



1. TO ALLOW PROPER ACCESS TO VALVES, DO NOT LOCATE VALVES ABOVE METAL CEILING LOCATED IN CORRIDOR 640, COMMUNITY LIVING ROOM 104, AND MULTIPURPOSE ROOM 105 UNLESS NOTED OTHERWISE.
2. PROVIDE 3/4" HWS/R PIPING TO TERMINAL UNITS, UNLESS NOTED OTHERWISE.
3. COORDINATE PIPING MANUAL HIGH POINT VENTS WITH CEILING ACCESS PANEL LOCATIONS.

A2

KEY NOTES

1. RADIANT WALL PANELS MOUNTED AT 10'-0" A.F.F ON MUILLIONS.
2. LOCATE HW DIFFERENTIAL PRESSURE SENSOR TRANSMITTER.
3. 3/4" HWS/DN TO RADIANT WALL PANEL AND 3/4" HWS/R TO TRENCH HEATER. VALVES SERVING TRENCH HEATER TO BE LOCATED WITHIN TRENCH OPENING.
4. LOCATE ALL VALVES AND CIRCUIT SETTERS ADJACENT TO ACCESS PANELS. REFER TO THE ARCHITECTURAL DRAWINGS FOR ACCESS PANEL LOCATIONS AND COORDINATE ACCORDINGLY.
5. 3/4" HWS/R DN TO TRENCH HEATER. VALVES SERVING TRENCH HEATER TO BE LOCATED WITHIN TRENCH OPENING.
6. PROVIDE CONDENSING UNIT WITH 4" CURB.
7. ROUTE RTU CONDENSATE DRAIN TO GRADE. PROVIDE FULLY TRAPPED AND SLOPED PIPING IN ACCORDANCE WITH MANUFACTURER'S REQUIREMENTS.
8. TO RADIANT WALL PANELS AND TRENCH HEATERS SERVING THE ASSOCIATED SPACE.


A2

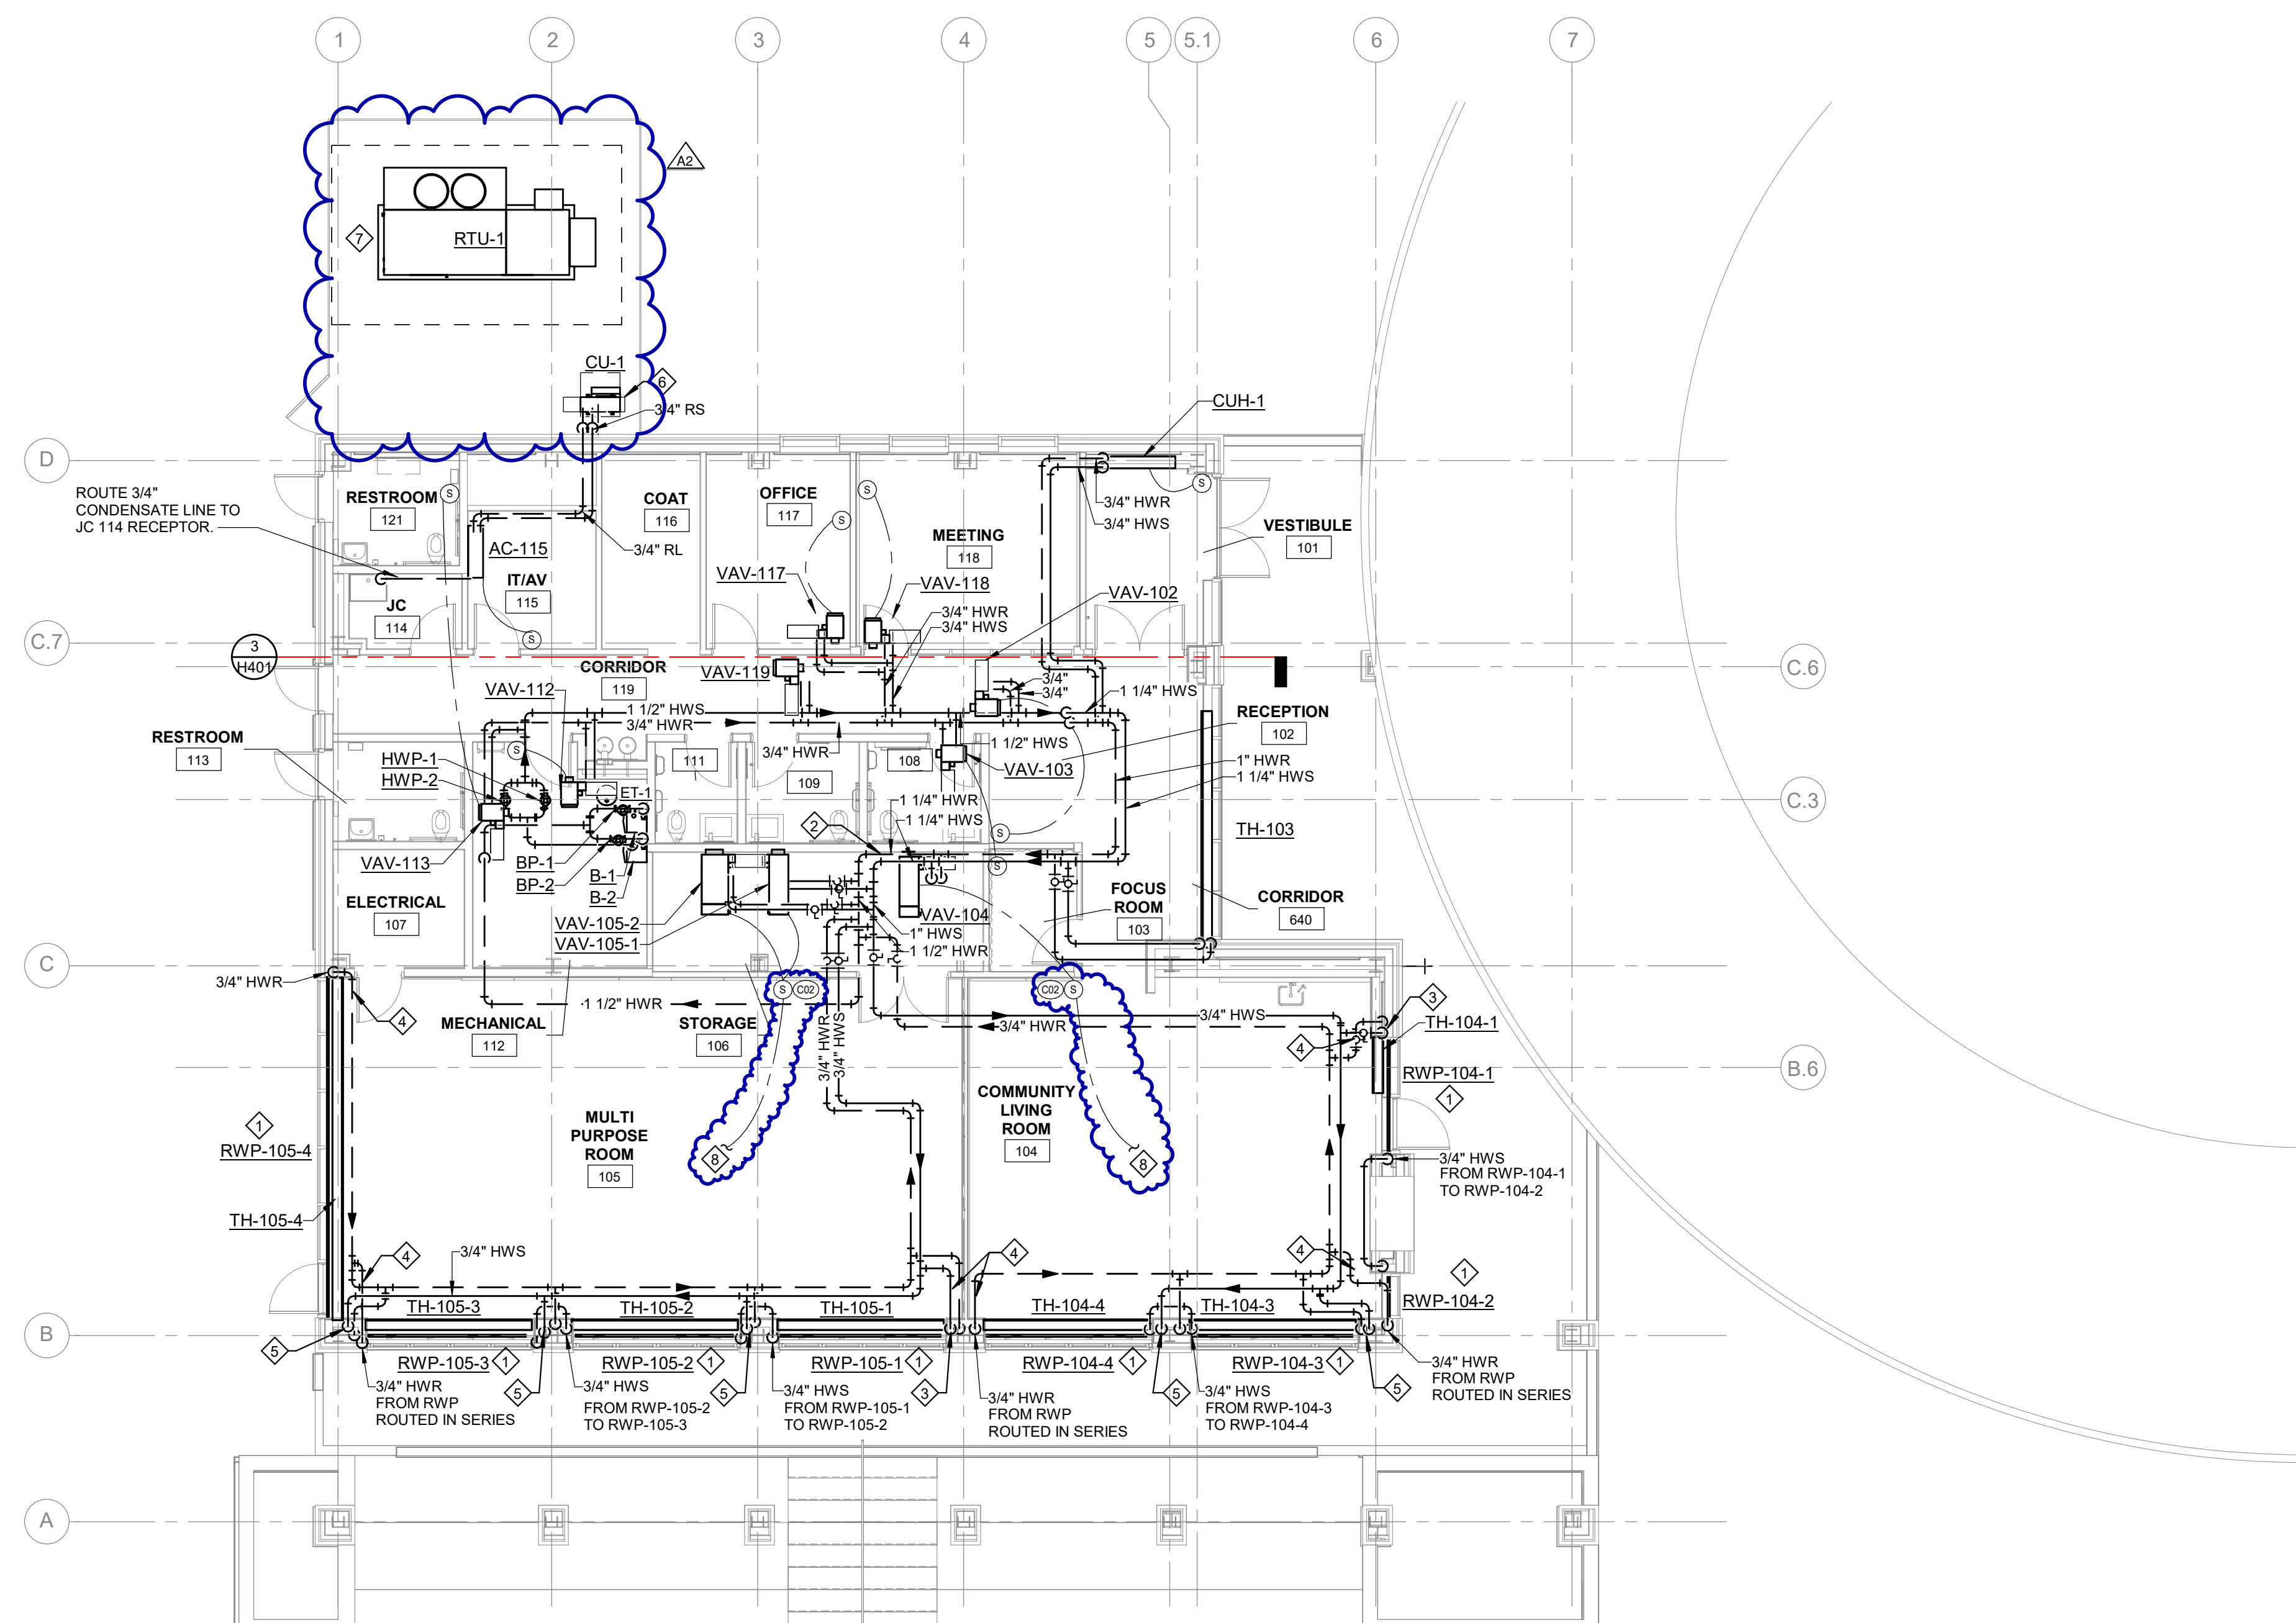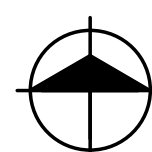


LAKE HOUSE HVAC PIPING PLAN - AREA A

SCALE: 1/8" = 1'-0"

KEY PLAN

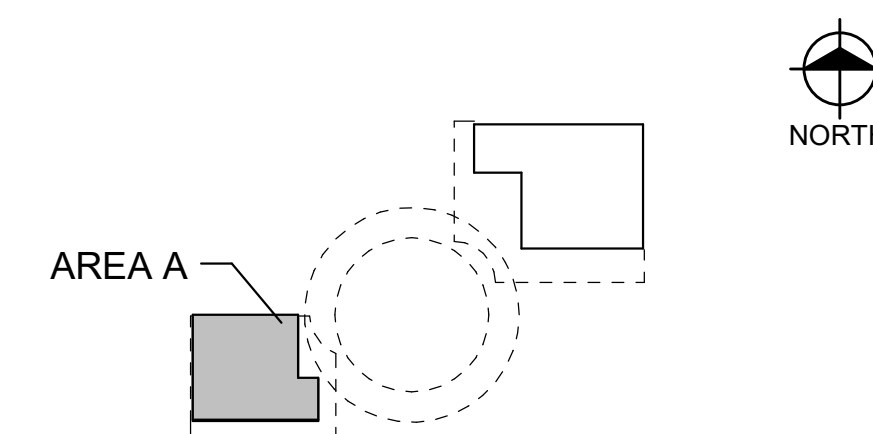

AREA A

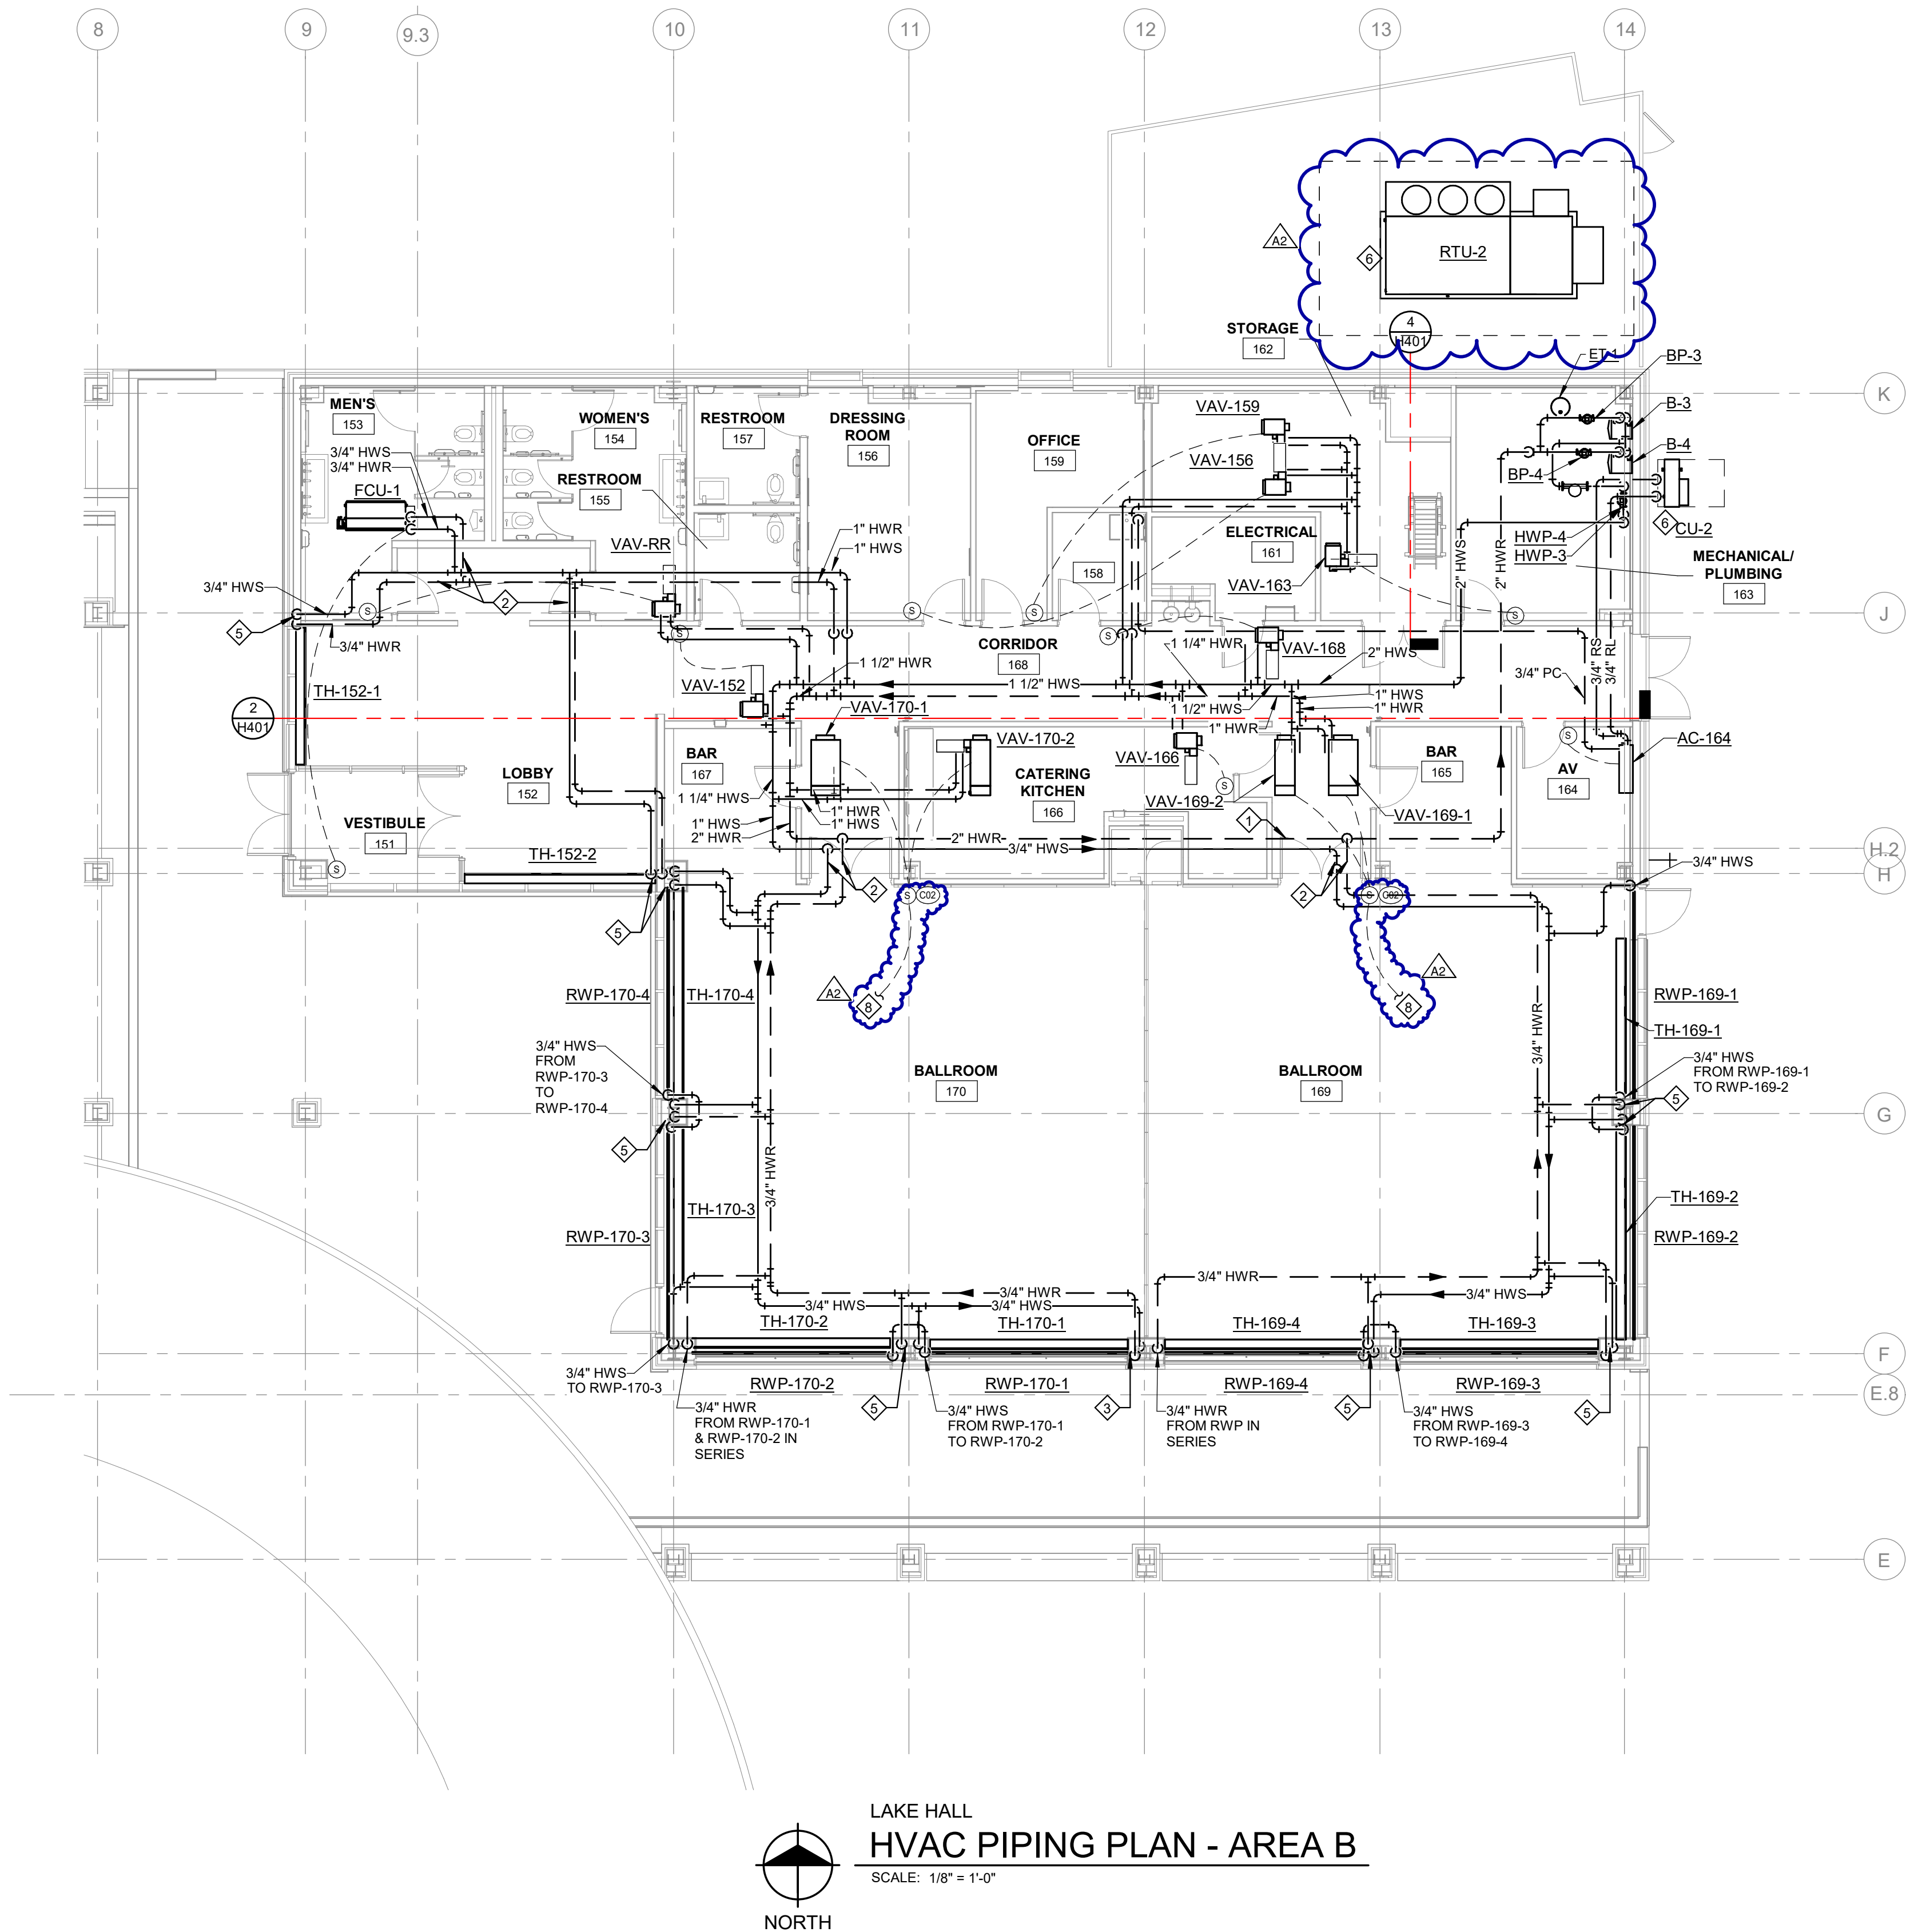


GENERAL NOTES

1. TO ALLOW PROPER ACCESS TO VALVES, DO NOT LOCATE VALVES ABOVE METAL CEILING LOCATED IN LOBBY 152, BALLROOM 169, AND 170 UNLESS NOTED OTHERWISE.
2. PROVIDE 3/4" HWS/R PIPING TO TERMINAL UNITS, UNLESS NOTED OTHERWISE.
3. COORDINATE PIPING MANUAL HIGH POINT VENTS WITH CEILING ACCESS PANEL LOCATIONS.

KEY NOTES

1. LOCATE HW DIFFERENTIAL PRESSURE SENSOR TRANSMITTER.
2. LOCATE VALVES WITHIN LAY-IN CEILING TO ALLOW ACCESS.
3. 3/4" HWS DN TO RADIANT WALL PANEL AND 3/4" HWS/R TRENCH HEATER. VALVES SERVING TRENCH HEATER TO BE LOCATED WITHIN TRENCH OPENING.
4. LOCATE ALL VALVES AND CIRCUIT SETTERS ADJACENT TO ACCESS PANELS. REFER TO THE ARCHITECTURAL DRAWINGS FOR ACCESS PANEL LOCATIONS AND COORDINATE ACCORDINGLY.
5. 3/4" HWS/R DN TO TRENCH HEATER. VALVES SERVING TRENCH HEATER TO BE LOCATED WITHIN TRENCH OPENING.
6. PROVIDE CONDENSING UNIT WITH 4" CURB.
7. ROUTE RTU CONDENSATE DRAIN TO GRADE. PROVIDE FULLY TRAPPED AND SLOPED PIPING IN ACCORDANCE WITH MANUFACTURER'S REQUIREMENTS.
8. TO RADIANT WALL PANELS AND TRENCH HEATERS SERVING THE ASSOCIATED SPACE.

KEY PLAN

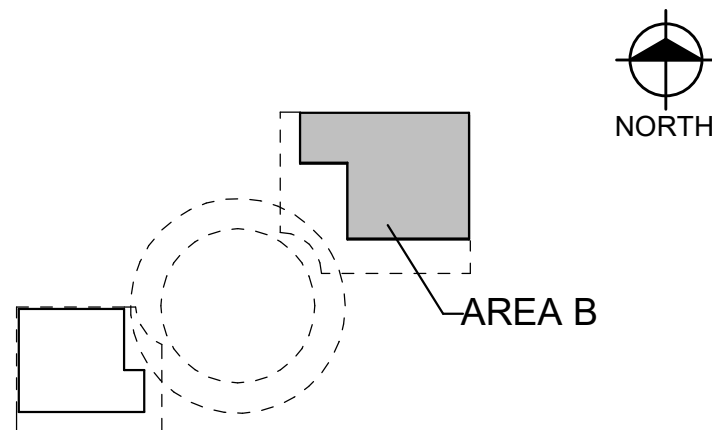

Van Buren Charter Township

Van Buren Township, MI

The Lakeside Park

REVISIONS		
10/27/2022	A2	ADDENDUM NO. 2

10/12/2026	BIDS & PERMIT
09/21/2026	CD PEER REVIEW
09/09/2026	CD TEAM REVIEW
08/10/2026	CD 50% PROGRESS
08/22/2026	DD OWNER REVIEW
06/15/2026	DD PEER REVIEW
06/08/2026	DD 90 % PROGRESS
05/18/2026	DD 50 % PROGRESS
02/23/2026	SD OWNER REVIEW
02/13/2026	SD PEER REVIEW
02/09/2026	SD PROGRESS REVIEW


Drawn By	CUHLIG
Designer	CUHLIG
Reviewer	GLOUIS
Manager	CKRETOVIC

Hard copy is intended to be 24"x36" when plotted. Scale(s) indicated and graphic quality may not be accurate for other size.


PROJECT NO.	2500281
SHEET NO.	

H202


PLOT INFO: 10/27/2026 9:28:40 AM Autodesk Docs://2500281 - Van Buren Twp Lake House/2026_M_2500281.rvt

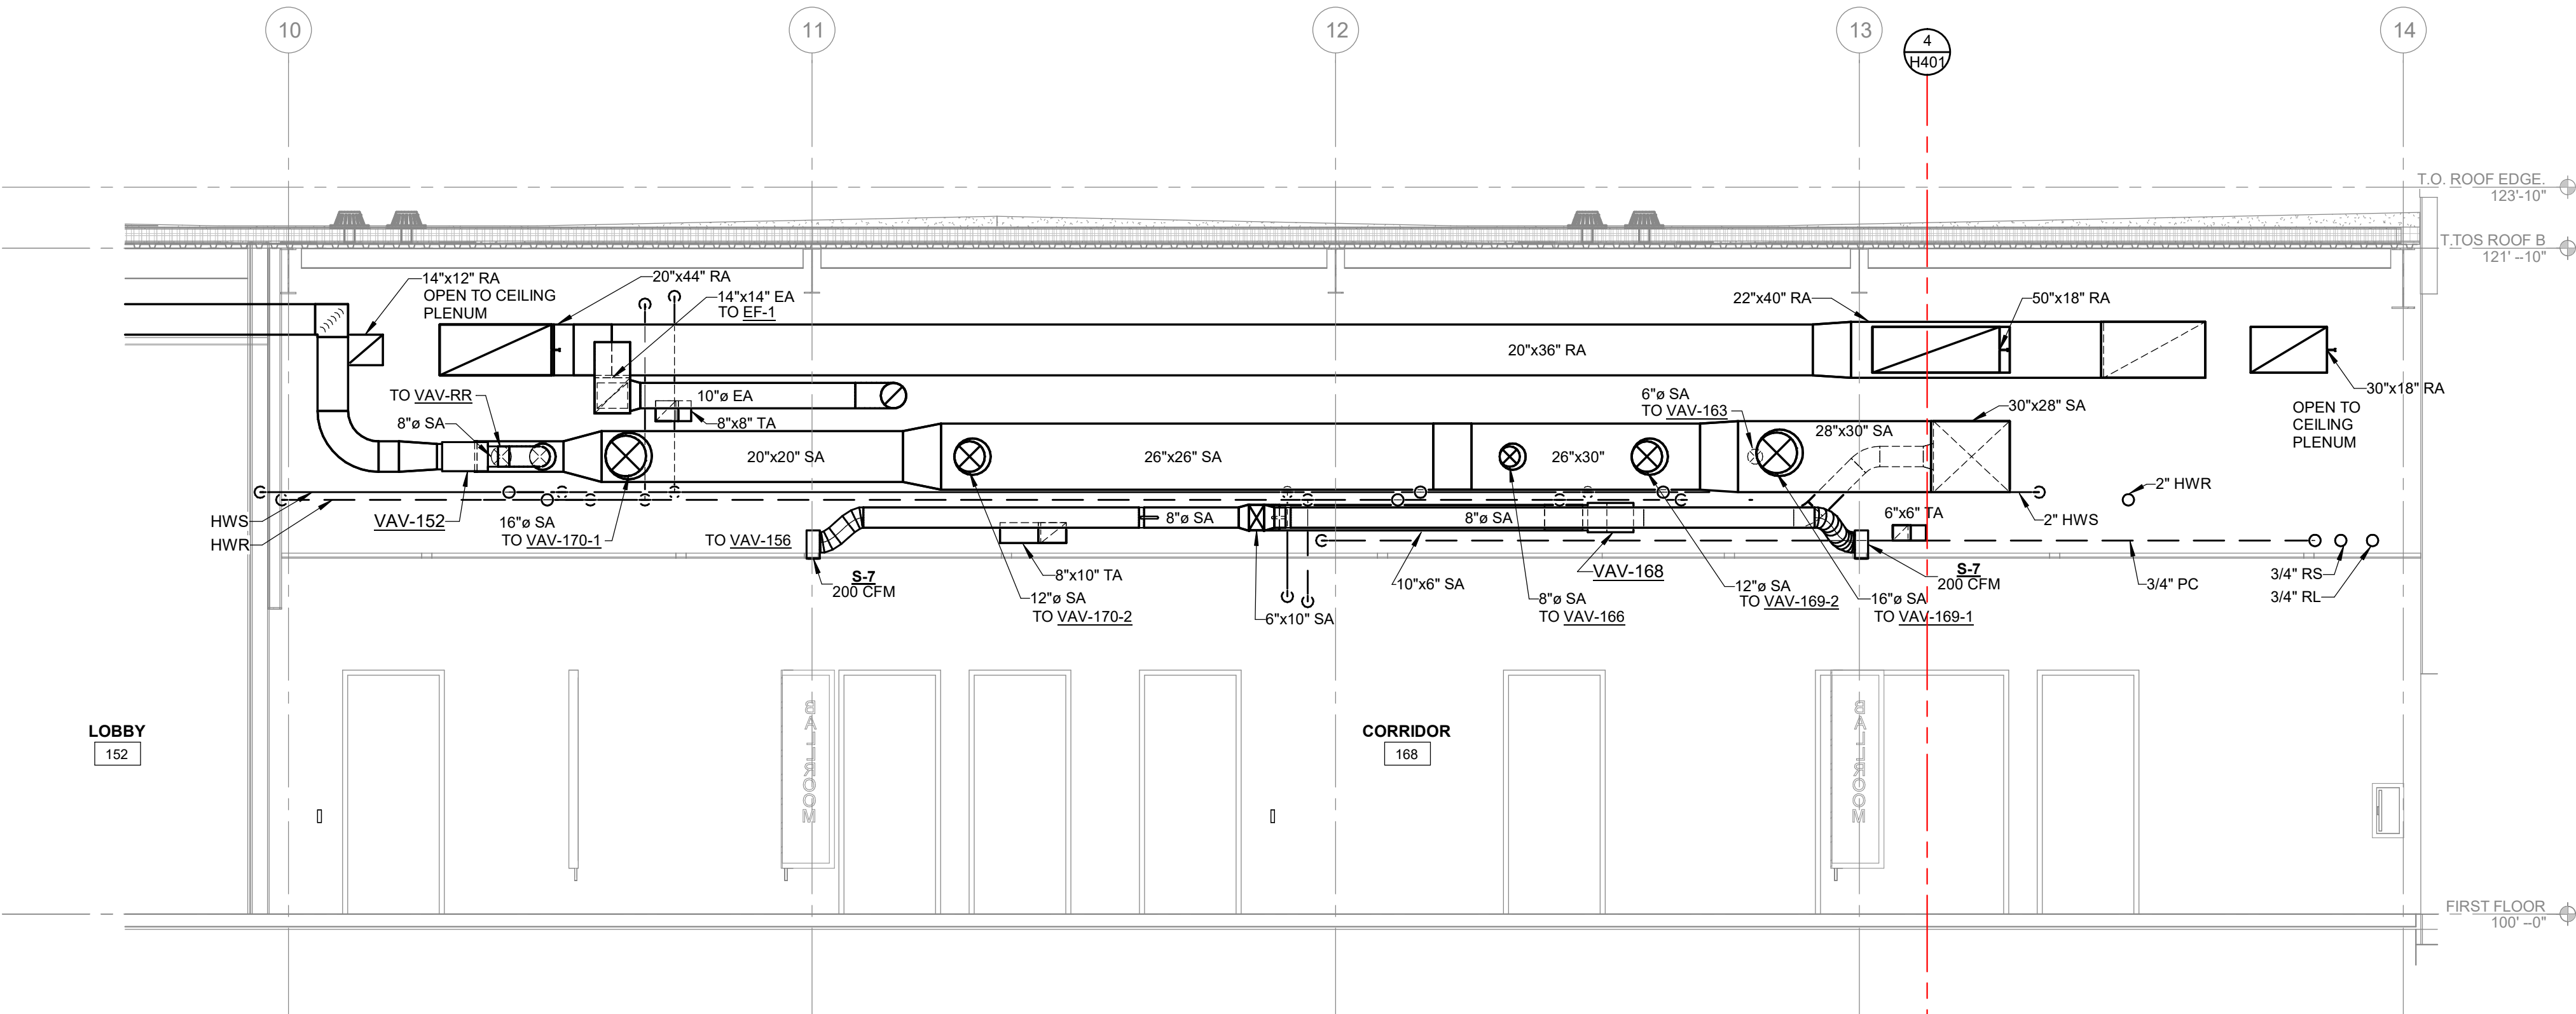


LAKE HALL
CORRIDOR SECTION
2
SCALE: 1/4" = 1'-0"

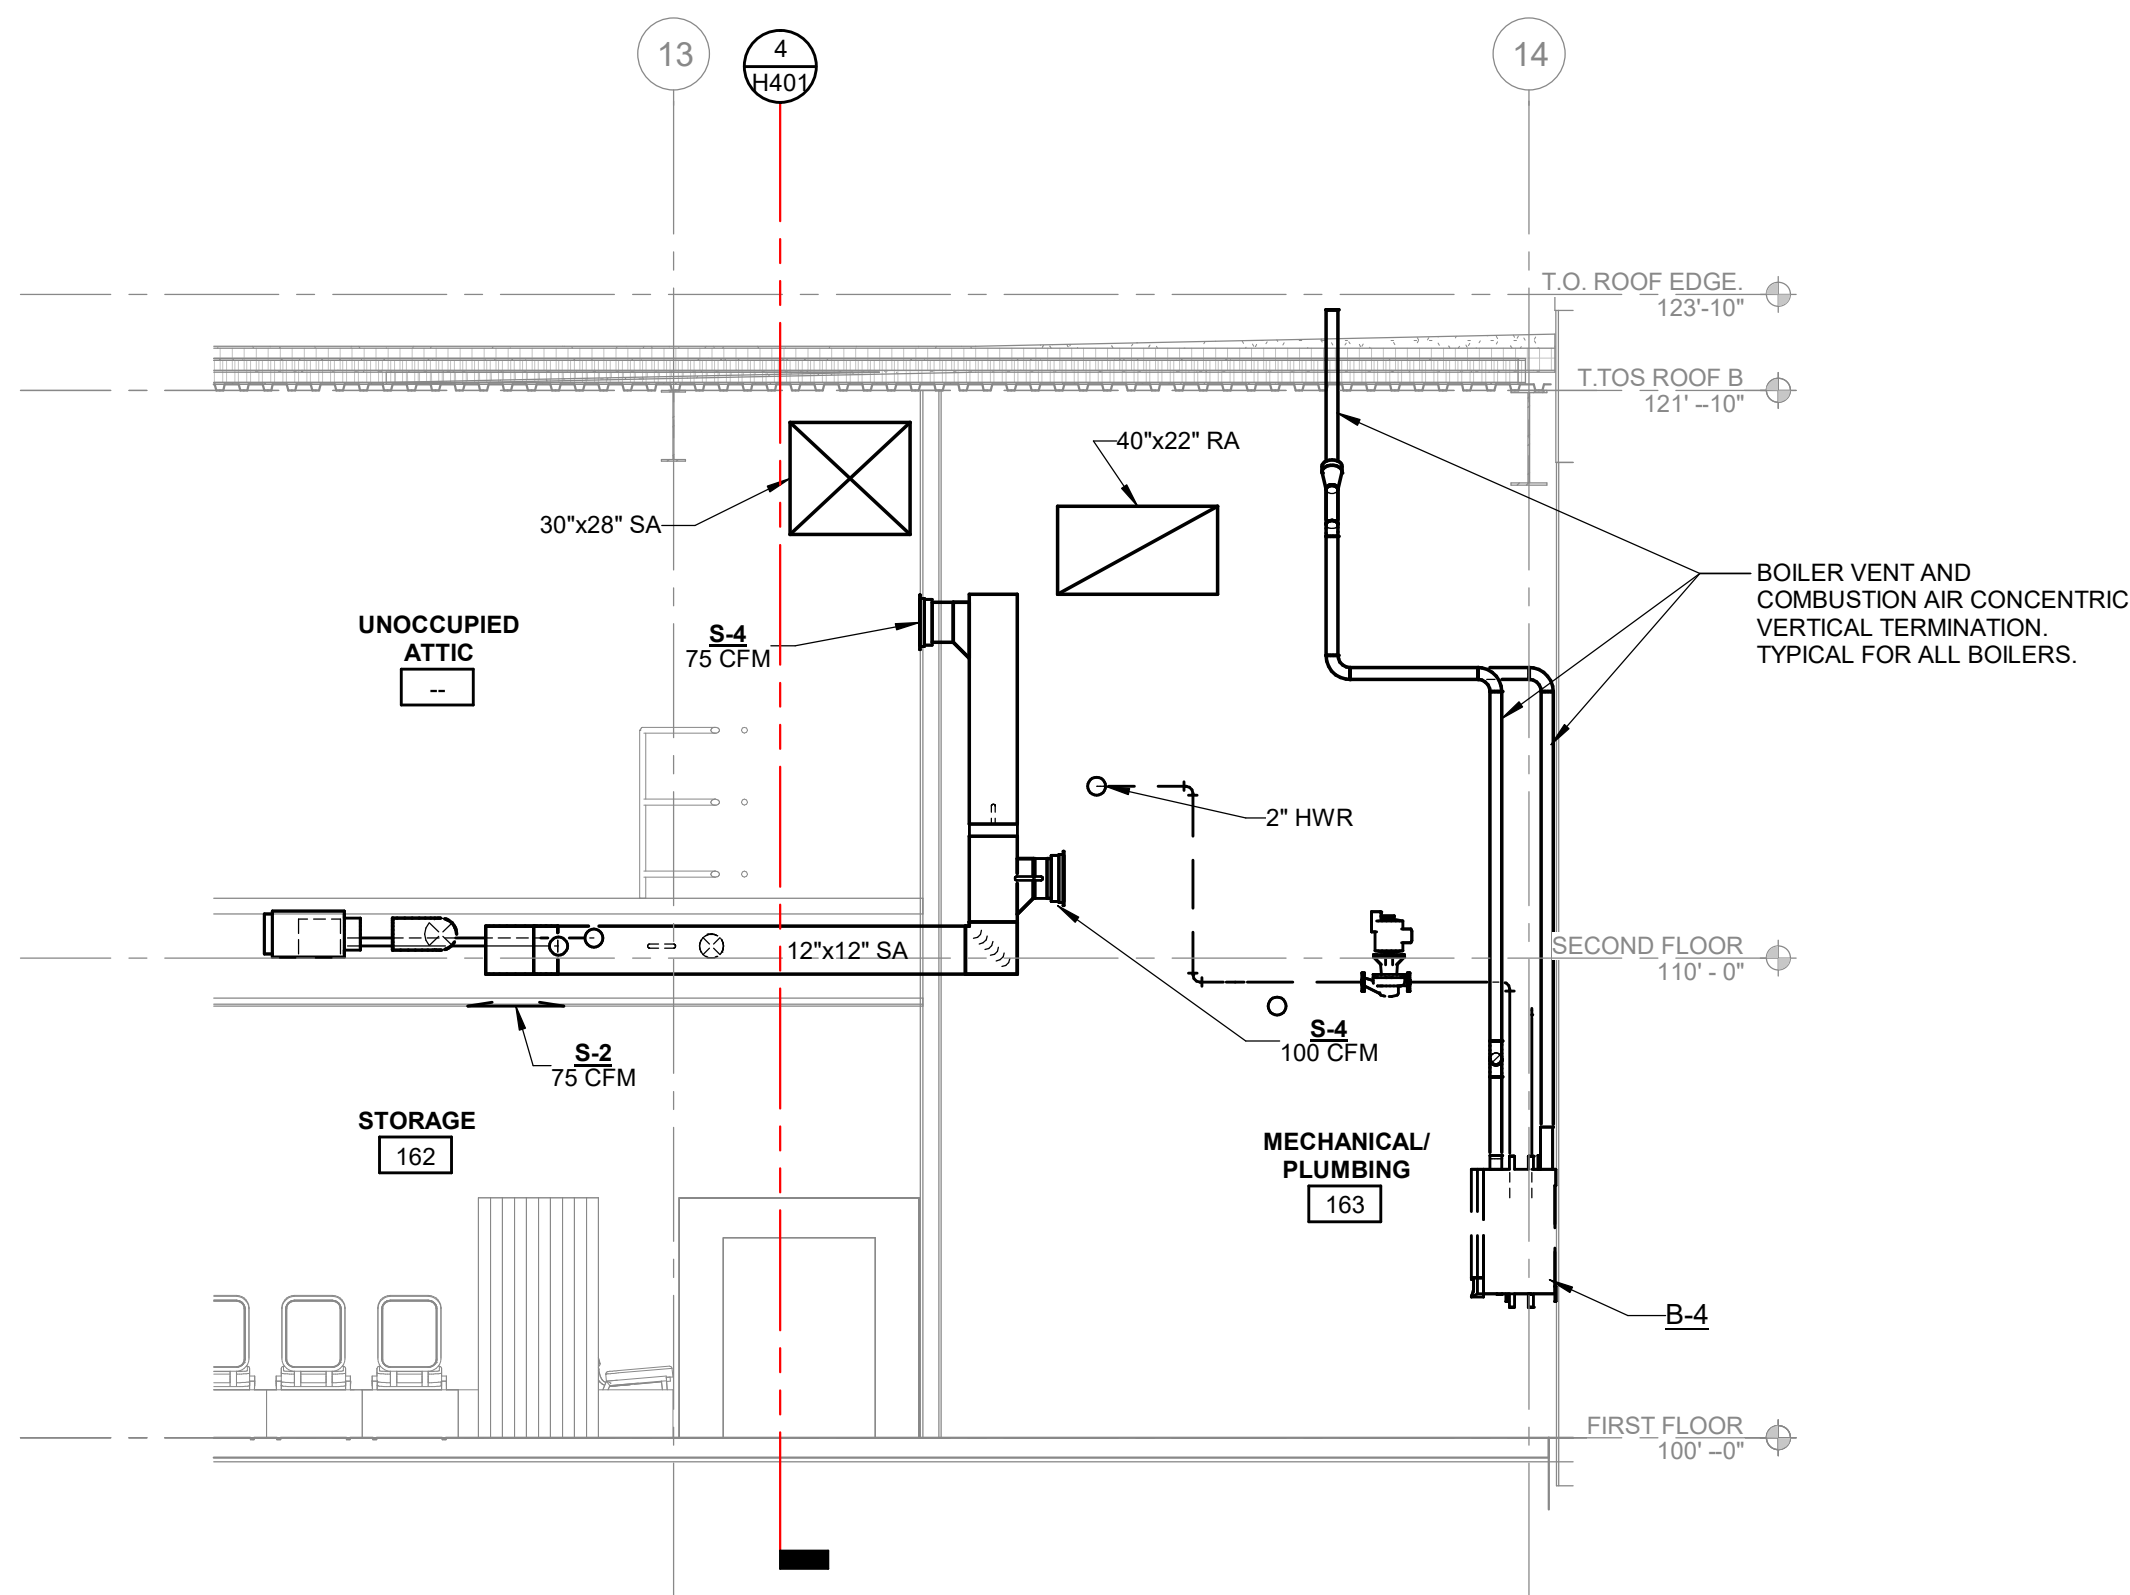

LAKE HALL
MEZZANINE SECTION
1
SCALE: 1/4" = 1'-0"

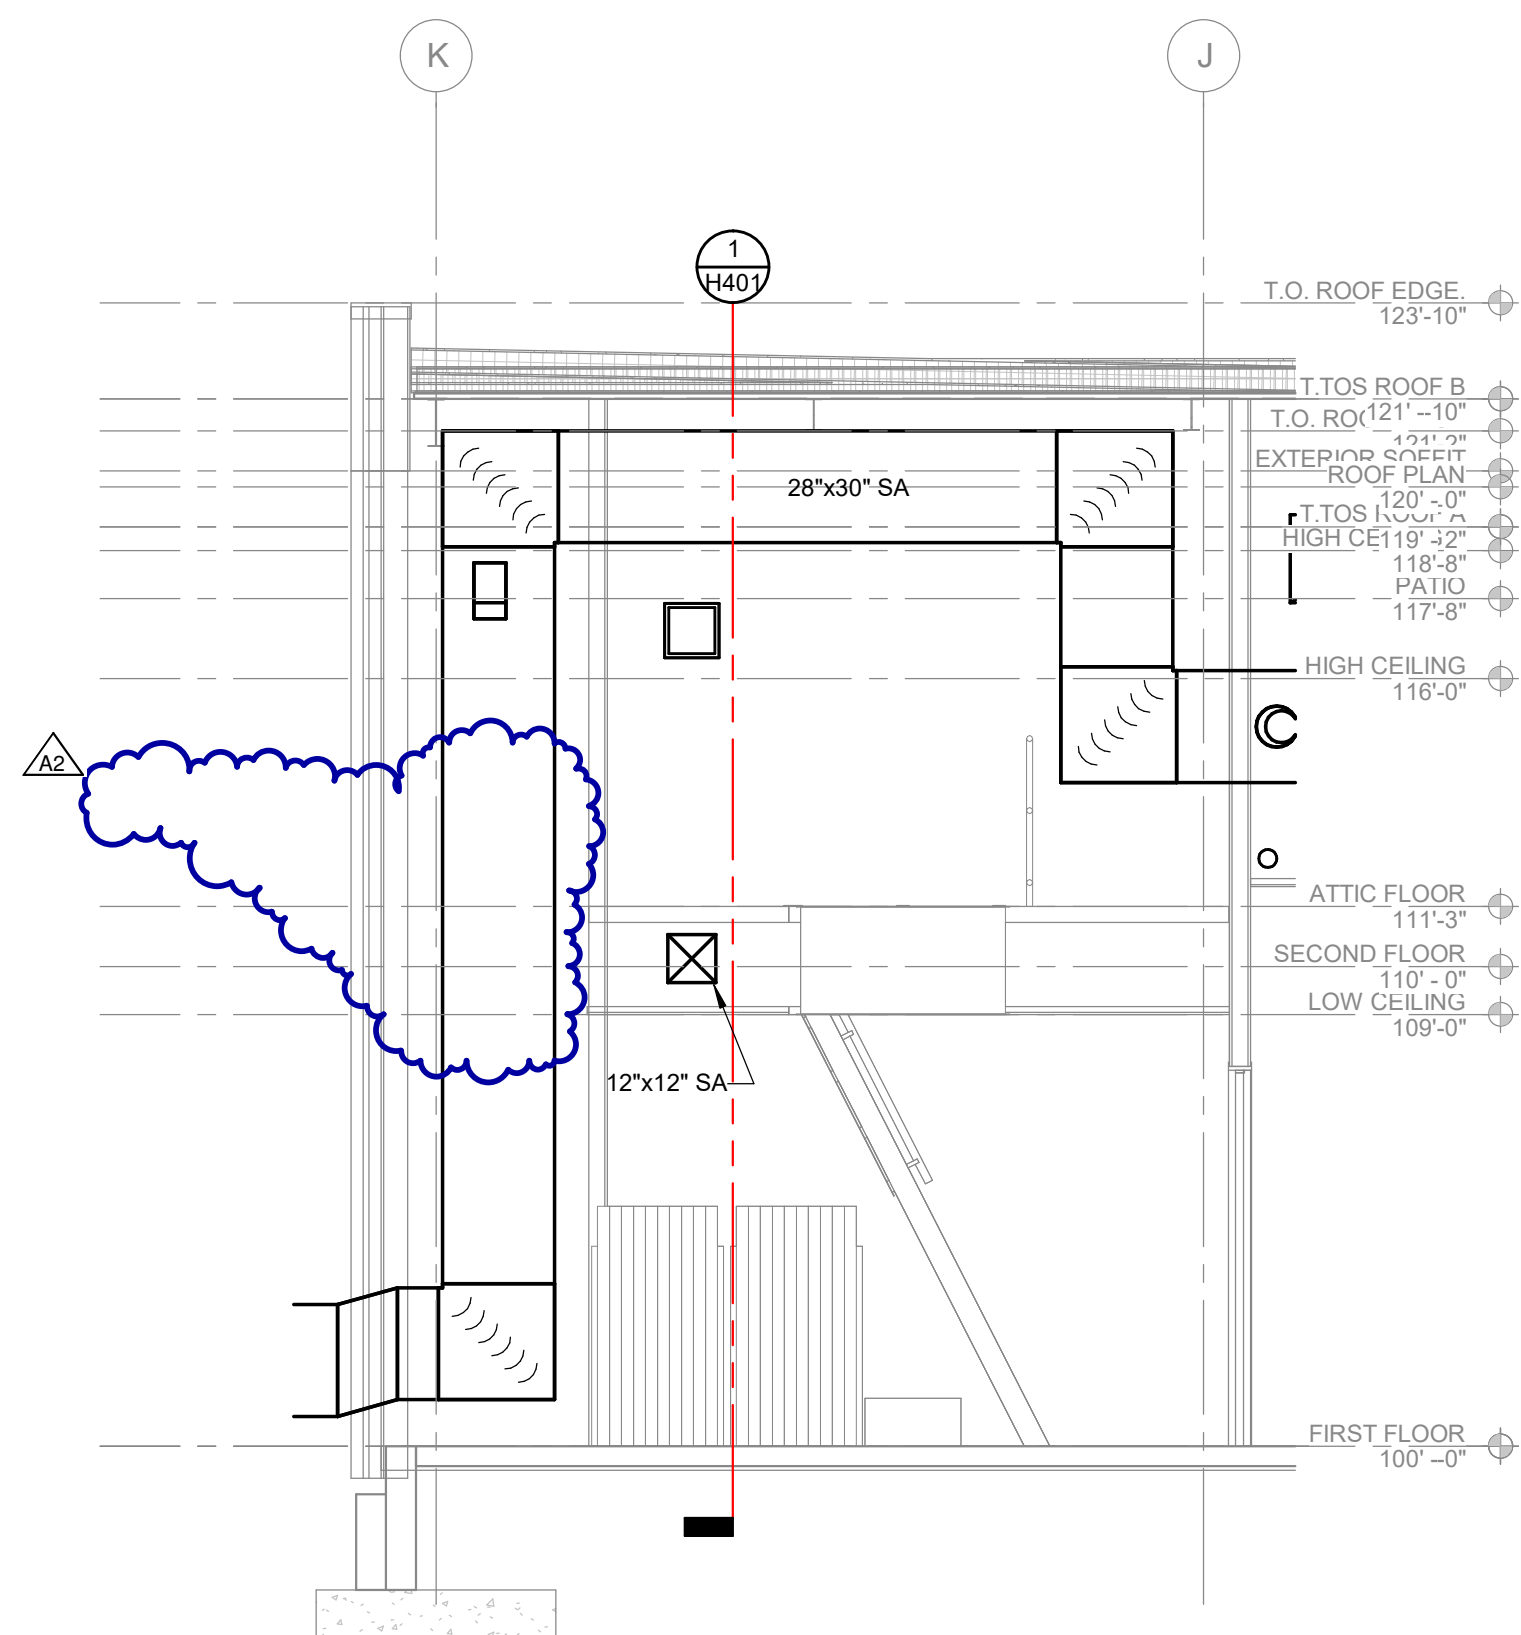

LAKE HOUSE ATTIC DUCT ROUTING
4
SCALE: 1/4" = 1'-0"

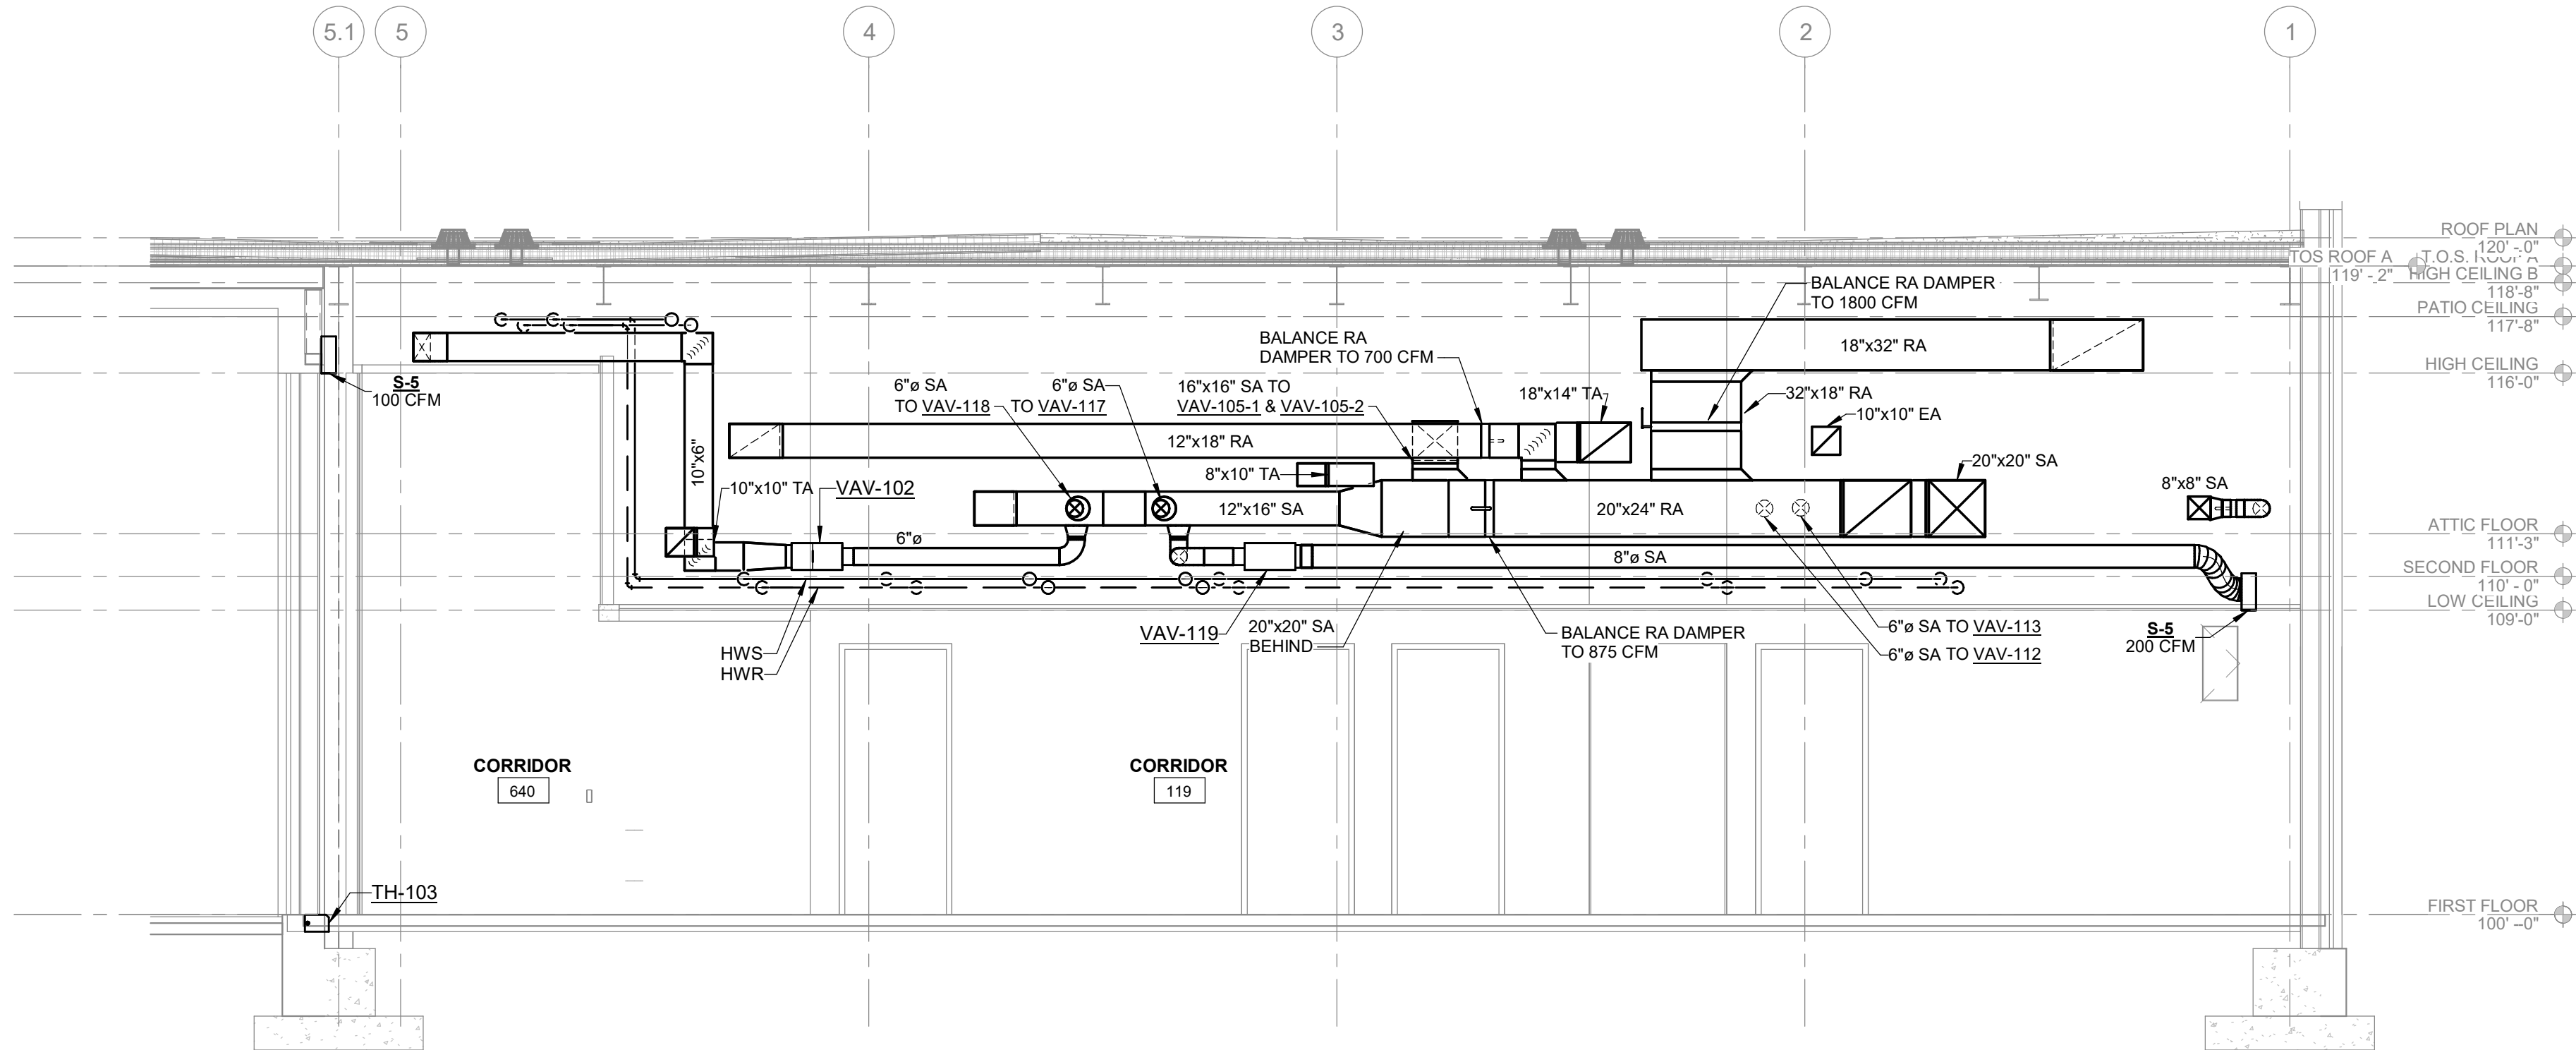

LAKE HOUSE
LAKE HOUSE CORRIDOR SECTION
3
SCALE: 1/4" = 1'-0"

Van Buren Charter Township

Van Buren Township, MI

The Lakeside Park

REVISIONS		
10/27/2022	A2	ADDENDUM NO. 2

10/12/2026	BIDS & PERMIT
09/21/2026	CD PEER REVIEW
09/09/2026	CD TEAM REVIEW
08/10/2026	CD 50% PROGRESS
08/22/2026	DD OWNER REVIEW
06/15/2026	DD PEER REVIEW
06/08/2026	DD 90 % PROGRESS
05/18/2026	DD 90 % PROGRESS
02/23/2026	SD OWNER REVIEW
02/13/2026	SD PEER REVIEW
02/09/2026	SD PROGRESS REVIEW

Drawn By	Author
Designer	Designer
Reviewer	Checker
Manager	CKRETOVIC

Hard copy is intended to be 24"x36" when plotted. Scale(s) indicated and graphic quality may not be accurate for any other size.

PROJECT NO.
2500281
SHEET NO.

H401

ROOFTOP UNIT SCHEDULE - GAS FIRED HEAT & DX COOLING

ID TAG	SERVICE	MANUFACTURER	MODEL	OUTDOOR AIR		SUPPLY FAN SECTION								DX COOLING SECTION								HOT-GAS REHEAT SECTION				INDIRECT GAS HEATING SECTION				EXHAUST FAN SECTION				ELECTRICAL				ACCESSORIES				WEIGHT (LBS)	NOTES							
				MAX CFM	MIN CFM	WHEEL TYPE	DRIVE TYPE	CFM	ESP (IN WC)	TSP (IN WC)	BHP	HP	RPM	VFD	EAT DB	EAT WB	LAT DB	LAT WB	SENSIBLE MBH	LATENT MBH	TOTAL MBH	NUMBER OF ROWS	EER	IEER	EAT DB	LAT DB	TOTAL MBH	CONTROL	EAT DB	LAT DB	TURN DOWN	AIR TEMP RISE (F)	INPUT MBH	OUTPUT MBH	GAS PRESSURE	WHEEL TYPE	DRIVE TYPE	RPM	ESP (IN WC)	BHP	VOLTAGE (V/PH/Hz)			MCA	MOCP	MIN EER	CURB	GFCI	CONTROL	DISCONNECT
RTU-1	LAKE HOUSE	VALENT	VX-112-12.5I-JJ3	3900	450		DIRECT	3900	2.1	3.32	3.34	5	2115	MANUF. PROVIDED	79	66	54	54	99.7	37	136.7		11.2	18.6		77	94.1	MODULATING	52.4	110	12.1	57.6	300	243	4.0"-14.0"		DIRECT	1170	0.2	1.33	208/3/60	78.1	110	11	BY MANUF.	BY ELECTRICAL	BACnet MSTP	BY MANUF.	2989	1,2,4,5
RTU-2	LAKE HALL	VALENT	VX-212-25I-M-J3	8100	1000		DIRECT	8100	2	3.788	8.96	10	2032	MANUF. PROVIDED	79.3	66.2	53	53	218.7	95	313.7	6	10.1	16.3		83.3	257.8	MODULATING	48.4	85.4	15.1	37	400	324	4.0"-14.0"		DIRECT	1594	0.2	3.62	208/3/60	140.5	175	9.8	BY MANUF.	BY ELECTRICAL	BACnet MSTP	BY MANUF.	4249	1,3,4,5

- NOTES:
- PROVIDE WITH HIGH STATIC KIT TO GET 2.3" ESP.
 - PROVIDE EQUIPMENT PAD THAT IS 13'2" x 5'0". REFER TO ISOLATED EQUIPMENT PAD STRUCTURAL DETAIL ON SHEET S002.
 - PROVIDE EQUIPMENT PAD THAT IS 14'-4" x 6'-4". REFER TO ISOLATED EQUIPMENT STRUTURAL DETAIL ON SHEET S002.
 - PROVIDE WITH FULL ECONOMIZER.
 - REFRIGERANT TYPE R454B.



REGISTER, GRILLE, AND DIFFUSER SCHEDULE

ID TAG	MANUFACTURER	MODEL	NECK SIZE (IN)	FACE SIZE (IN)	MAX CFM	MAX APD	MAX NC	MATERIAL	MOUNTING	FINISH	DAMPER (Y/N)	NOTES
E-1	TITUS	50F	<varies>	12x12	528	0.054		STEEL	ACP	WHITE	NO	
E-2	TITUS	50F	N/A	24x24	2250	0.054	14	STEEL	ACP	WHITE	NO	
R-1	TITUS	50F	N/A	24x24	2250	0.054	14	STEEL	ACP	WHITE	NO	
R-2	TITUS	FL-10	N/A	4 FT. (2) 1" SLOTS	200	0.028	10	STEEL	NOTE 2	BLACK	NO	
R-3	TITUS	FL-25	12	4 FT. (2) 2.5" SLOTS	1200	0.068	25	STEEL	NOTE 2	BLACK	NO	3
S-1	TITUS	OMNI	6	12x12	118	<varies>	<varies>	STEEL	<varies>	WHITE	NO	
S-2	TITUS	OMNI	6	24x24	196	0.099	21	STEEL	ACP	WHITE	NO	
S-3	TITUS	OMNI	8	24x24	279	0.064	19	STEEL	ACP	WHITE	NO	
S-4	TITUS	111RL	10x10	12x12	354	0.065	15	STEEL	SIDEWALL	WHITE	NO	
S-5	TITUS	FL-10	8	4 FT. (2) 1" SLOTS	230	0.064	10	STEEL	NOTE 2	BLACK	YES	1,3,4,5
S-6	TITUS	FL-15	12	4 FT. (2) 1.5" SLOTS	360	0.087	18	STEEL	NOTE 2	BLACK	YES	1,3,4,5
S-7	TITUS	FL-10	8	6 FT. (2) 1" SLOTS	230	0.064	10	STEEL	NOTE 2	BLACK	YES	1,3,4,5
S-8	TITUS	FL-10-JT	8	4 FT. (1) 1" SLOT	250	0.099	18	STEEL	NOTE 2	BLACK	YES	1,3,4,5
S-9	TITUS	FL-25-JT	12	4 FT. (2) 2.5" SLOTS	1260	0.235	25	STEEL	NOTE 2	BLACK	YES	1,3,4,5

- NOTES:
- PROVIDE YOUNG REGULATOR COMPANY 270-275 WITH 5020CC DAMPER FOR REMOTE DAMPER CONTROL.
 - PROVIDE WITH TITUS CEILING/CEILING BORDER 66 WITH HANGER CLIP FOR MOUNTING IN CONTINUOUS CEILING SECTIONS.
 - PROVIDE DIFFUSER WITH 4" ATTACHED PLENUM.
 - DIFFUSERS GOING INTO PCS1a CEILING NEED HAVE A WIDTH OF LESS THAN 7 3/4".
 - LINEAR SLOT DIFFUSER WITH (2) SLOTS TO BE 2CRA STYLE.

VAV TERMINAL UNIT SCHEDULE

ID TAG	MANUFACTURER	MODEL	SIZE	CFM			REHEAT COIL					VALVE			NOTES	
				MAX	MIN	HEATING	EWT (F)	GPM	EAT (F DB)	LAT (F DB)	APD* (IN WC)	WPD (FT HD)	# OF ROWS	2-WAY		3-WAY
VAV-102	TITUS	DESV	6"	200	100	100	140	0.8	55	85	0.06	0.14	2	Yes	No	
VAV-103	TITUS	DESV	6"	100	50	50	140	0.8	55	85	0.02	0.14	2	Yes	No	
VAV-104	TITUS	DESV	10"	700	350	350	140	1.3	55	85	0.16	0.19	2	Yes	No	1
VAV-105-1	TITUS	DESV	10"	500	250	250	140	0.9	55	85	0.17	0.2	2	Yes	No	1
VAV-105-2	TITUS	DESV	14"	1300	650	650	140	2.7	55	85	0.14	0.37	2	Yes	No	1
VAV-112	TITUS	DESV	6"	150	75	75	140	0.8	55	85	0.04	0.14	2	Yes	No	
VAV-113	TITUS	DESV	6"	300	150	300	140	0.8	55	85	0.08	0.14	2	Yes	No	
VAV-117	TITUS	DESV	6"	225	115	225	140	0.8	55	85	0.08	0.14	2	Yes	No	
VAV-118	TITUS	DESV	6"	250	125	125	140	0.8	55	85	0.09	0.14	2	Yes	No	
VAV-119	TITUS	DESV	6"	200	100	100	140	0.8	55	85	0.06	0.14	2	Yes	No	
VAV-152	TITUS	DESV	8"	400	200	200	140	0.8	55	85	0.12	0.19	2	Yes	No	
VAV-156	TITUS	DESV	8"	275	140	140	140	0.8	55	85	0.07	0.19	2	Yes	No	
VAV-159	TITUS	DESV	6"	150	75	75	140	0.8	55	85	0.04	0.14	2	Yes	No	
VAV-163	TITUS	DESV	6"	250	125	175	140	0.8	55	85	0.09	0.14	2	Yes	No	
VAV-166	TITUS	DESV	8"	400	200	200	140	0.8	55	85	0.12	0.19	2	Yes	No	
VAV-168	TITUS	DESV	8"	400	200	200	140	0.8	55	85	0.12	0.19	2	Yes	No	
VAV-169-1	TITUS	DESV	16"	1800	900	900	140	3.3	55	85	0.18	0.23	2	Yes	No	1
VAV-169-2	TITUS	DESV	12"	900	450	450	140	1.8	55	85	0.15	0.34	2	Yes	No	1
VAV-170-1	TITUS	DESV	16"	1600	800	800	140	3.1	55	85	0.2	0.42	2	Yes	No	1
VAV-170-2	TITUS	DESV	12"	1000	500	500	140	1.8	55	85	0.15	0.34	2	Yes	No	1
VAV-RR	TITUS	DESV	8"	450	225	265	140	0.9	55	85	0.15	0.22	2	Yes	No	

- NOTES:
- PROVIDE WITH DUCT ATTENUATOR AT VAV BOX OUTLET.

FAN SCHEDULE

ID TAG	LOCATION	SERVICE	MANUFACTURER	MODEL	FAN TYPE	CFM	TSP (IN WC)	ESP (IN WC)	MOTOR HP	MAX BHP	FAN RPM	WHEEL			DRIVE TYPE	SOUND		VOLTAGE (V/PH/Hz)	MOTOR CONTROLLER		MAX WEIGHT (LBS)	NOTES
												MATERIAL	DIA (IN)	TYPE		SONES	DBA		MOTOR STARTER (E/S)	DISCONNECT SWITCH (E/S)		
EF-1	ROOF	LAKE HOUSE	GREENHECK	G-090-VG	EXHAUST	450	0.70	0.50	0.17	0.09	1655	ALUMINUM	10 7/8"	CENTRIFUGAL	DIRECT	8.2	56	208/60/1	ECM	S	41	1,2
EF-2	ROOF	LAKE HALL	GREENHECK	G-120-VG	EXHAUST	925	0.70	0.50	0.25	0.13	1104	ALUMINUM	13 1/16"	CENTRIFUGAL	DIRECT	7.6	55	208/60/1	ECM	S	59	1,2

- NOTES:
- PROVIDE A FACTORY MOUNTED ELECTRONICALLY COMMUTATED (EC) MOTOR WITH INTEGRAL DRIVE.
 - MANUFACTURER TO PROVIDE 14" HIGH ROOF CURB.

SPLIT SYSTEM INDOOR UNIT SCHEDULE

ID TAG	SERVICE	MANUFACTURER	MODEL	TYPE	NOMINAL TONS	ODU ID TAG	SUPPLY FAN	COOLING		ELECTRICAL		ACCESSORIES			WEIGHT (LBS)	NOTES
							SA CFM	SENSIBLE MBH	TOTAL MBH	VOLTAGE (V/PH/Hz)	MCA	COND PUMP	CONTROL	DISCONNECT		
AC-115	IT/AV-115	mitsubishi electric	MSY-GX18NL	WALL MOUNT	1.5	CU-1	324	14.22	18	208/1/60	1	YES	THERMOSTAT	INCLUDE	37	1,2
AC-164	AV-164	mitsubishi electric	PKA-AK30NL	WALL MOUNT	2.5	CU-2	635	18.6	30	208/1/60	1	YES	THERMOSTAT	INCLUDE	45	1,2,3

- NOTES:
- MOUNT 1'-0" ABOVE IT/AV CABLE TRAY, APPROXIMATELY 86" A.F.F
 - MANUFACTURER TO PROVIDE REMOTE WALL MOUNTED THERMOSTAT.
 - PROVIDE WITH CONDENSATE PUMP.

SPLIT SYSTEM OUTDOOR UNIT SCHEDULE

ID TAG	SERVICE	MANUFACTURER	MODEL	TYPE	NOMINAL TONS	IDU ID TAG	REFRIGERANT	COOLING			COMPRESSORS		ELECTRICAL		DBA	DISCONNECT	WEIGHT (LBS)	NOTES
								AMB (H/L/OW)	SENSIBLE MBH	TOTAL MBH	EFFICIENCY (SEER2)	QUANTITY	TYPE	VOLTAGE (V/PH/Hz)	MCA	MOCP		
CU-1	LAKE HOUSE AV ROOM	mitsubishi electric	MUY-GX18NL	COOLING ONLY	1.5	AC-115	R454B	95	14.22	18	22.5	1	TWIN ROTARY	208/1/60	23	25	54	
CU-2	LAKE HALL AV ROOM	mitsubishi electric	PUY-AH30NL	COOLING ONLY	2.5	AC-164	R454B	95	18.6	30	19.7	1	TWIN ROTARY	208/1/60	22	37	49	

HYDRONIC CABINET HEATER SCHEDULE

ID TAG	SERVICE	MANUFACTURER	MODEL	TYPE	FAN		HYDRONIC HEATING SECTION						ELECTRICAL		ACCESSORIES		WEIGHT (LBS)	NOTES	
					CFM	HP	EAT DB	OUTPUT MBH	FLUID	EWT (F)	LWT (F)	GPM	WPD (FT HD)	VOLTAGE (V/PH/Hz)	FLA	CONTROL			DISCONNECT
CUH-1	LAKE HOUSE VESTIBULE	ZEHNDER-RITTLING	RC/W-420-06	WALL RECESSED	620	1/15	65	24.7	WATER	140	100	1.3	0.6	120/1/60	1.13	THERMOSTAT	BY MANUF.	130	

FAN COIL UNIT SCHEDULE

ID TAG	SERVICE	MANUFACTURER	MODEL	SUPPLY FAN				HEATING COIL						ELECTRICAL				CONTROL	WEIGHT	NOTES
				CFM	ESP (IN WC)	BHP	HP	EAT (F DB)	LAT (F DB)	EWT (F)	LWT (F)	GPM	WPD (FT HD)	VOLTAGE (V/PH/Hz)	FLA	MCA	MOCP			
FCU-1	LAKE HALL VESTIBULE	ENVIRO-TEC	HLP-D SIZE 10	1100	0.5	0.17	(2) 1/4	50	76	140	120	3.12	1.89	115/1/60	5.8	6.52	15	3-SPEED ADJUSTABLE	102	1

- NOTES:
- MANUFACTURER TO PROVIDE REMOTE WALL MOUNTED THERMOSTAT.

REVISIONS

10/27/2022	A2	ADDENDUM NO. 2
------------	----	----------------

10/12/2026	BIDS & PERMIT
09/21/2026	CD PEER REVIEW
09/09/2026	CD TEAM REVIEW
08/10/2026	CD 50% PROGRESS
08/02/2026	DD OWNER REVIEW
06/15/2026	DD PEER REVIEW
06/08/2026	DD 90 % PROGRESS
05/18/2026	DD 90 % PROGRESS
02/23/2026	SD OWNER REVIEW
02/13/2026	SD PEER REVIEW
02/09/2026	SD PROGRESS REVIEW

Drawn By CUHLIG
Designer CUHLIG
Reviewer GLOUIS
Manager CKRETOVIC

Hard copy is intended to be 24"x36" when plotted. Scale(s) indicated and graphic quality may not be accurate for any other size.

PROJECT NO.

2500281

SHEET NO.

H701

PLOT INFO: 10/27/2025 9:28:41 AM Autodesk Docs://500281 - Van Buren Twp Lake House/2006_M_2500281.rvt

MISCELLANEOUS EQUIPMENT SCHEDULE	
ID TAG	DESCRIPTION
AS-1	AIR SEPARATOR, SPIROTHERM MODEL VJR-1C. MAX FLOW OF 40 GPM.
ET-1	PRESSURIZED EXPANSION TANK, AMTROL MODEL AX-10-DD
SS-1	SIDE STREAM FILTER , SHELCO MODEL F0-78

IN-FLOOR TRENCH HEATER SCHEDULE													
ID TAG	SERVICE	MANUFACTURER	MODEL	TYPE	BTUH	TRENCH LENGTH	TRENCH WIDTH	HEIGHT	MOUNTING	CFM	FLUID	AVERAGE WATER TEMP (F)	GPM
TH-103	PERIMETER HEAT	KAMPMANN	KATHERM QK 215	FAN ASSISTED TRENCH HEATER	3266	116"	8.5"	6"	IN FLOOR	86	WATER	130	0.28
TH-104-1	PERIMETER HEAT	KAMPMANN	KATHERM QK 215	FAN ASSISTED TRENCH HEATER	544	30"	8.5"	6"	IN FLOOR	23	WATER	130	0.05
TH-104-3	PERIMETER HEAT	KAMPMANN	KATHERM QK 215	FAN ASSISTED TRENCH HEATER	3266	116"	8.5"	6"	IN FLOOR	86	WATER	130	0.28
TH-104-4	PERIMETER HEAT	KAMPMANN	KATHERM QK 215	FAN ASSISTED TRENCH HEATER	3266	116"	8.5"	6"	IN FLOOR	86	WATER	130	0.28
TH-105-1	PERIMETER HEAT	KAMPMANN	KATHERM QK 215	FAN ASSISTED TRENCH HEATER	3266	116"	8.5"	6"	IN FLOOR	86	WATER	130	0.28
TH-105-2	PERIMETER HEAT	KAMPMANN	KATHERM QK 215	FAN ASSISTED TRENCH HEATER	3266	116"	8.5"	6"	IN FLOOR	86	WATER	130	0.28
TH-105-3	PERIMETER HEAT	KAMPMANN	KATHERM QK 215	FAN ASSISTED TRENCH HEATER	3266	116"	8.5"	6"	IN FLOOR	86	WATER	130	0.28
TH-105-4	PERIMETER HEAT	KAMPMANN	KATHERM QK 215	FAN ASSISTED TRENCH HEATER	3266	116"	8.5"	6"	IN FLOOR	86	WATER	130	0.28
TH-152-1	PERIMETER HEAT	KAMPMANN	KATHERM QK 215	FAN ASSISTED TRENCH HEATER	3266	116"	8.5"	6"	IN FLOOR	86	WATER	130	0.28
TH-152-2	PERIMETER HEAT	KAMPMANN	KATHERM QK 215	FAN ASSISTED TRENCH HEATER	3266	116"	8.5"	6"	IN FLOOR	86	WATER	130	0.28
TH-169-1	PERIMETER HEAT	KAMPMANN	KATHERM QK 215	FAN ASSISTED TRENCH HEATER	3266	116"	8.5"	6"	IN FLOOR	86	WATER	130	0.28
TH-169-2	PERIMETER HEAT	KAMPMANN	KATHERM QK 215	FAN ASSISTED TRENCH HEATER	3266	116"	8.5"	6"	IN FLOOR	86	WATER	130	0.28
TH-169-3	PERIMETER HEAT	KAMPMANN	KATHERM QK 215	FAN ASSISTED TRENCH HEATER	3266	116"	8.5"	6"	IN FLOOR	86	WATER	130	0.28
TH-169-4	PERIMETER HEAT	KAMPMANN	KATHERM QK 215	FAN ASSISTED TRENCH HEATER	3266	116"	8.5"	6"	IN FLOOR	86	WATER	130	0.28
TH-170-1	PERIMETER HEAT	KAMPMANN	KATHERM QK 215	FAN ASSISTED TRENCH HEATER	3266	116"	8.5"	6"	IN FLOOR	86	WATER	130	0.28
TH-170-2	PERIMETER HEAT	KAMPMANN	KATHERM QK 215	FAN ASSISTED TRENCH HEATER	3266	116"	8.5"	6"	IN FLOOR	86	WATER	130	0.28
TH-170-3	PERIMETER HEAT	KAMPMANN	KATHERM QK 215	FAN ASSISTED TRENCH HEATER	3266	116"	8.5"	6"	IN FLOOR	86	WATER	130	0.28
TH-170-4	PERIMETER HEAT	KAMPMANN	KATHERM QK 215	FAN ASSISTED TRENCH HEATER	3266	116"	8.5"	6"	IN FLOOR	86	WATER	130	0.28
NOTES: 1. PROVIDE WITH EXTENDED TRENCH TO COVER ENTIRE DISTANCE BETWEEN COLUMNS 2. PROVIDE WITH ROLL UP GRILLE FOR MAINTENANCE TO ALLOW GRILLES TO BE REMOVED AND CLEANED PERIODICALLY. 3. PROVIDE 24V POWER FOR FAN. 4. STAINLESS STEEL GRILLE 5. EPOXY-COATED ELEMENT 6. POWER-COATED OR ANODIZED VISIBLE METAL. 7. LEGS TO ACCOMMODATE 8" DEEP TRENCH.													

DUCT SILENCER SCHEDULE																	
ID TAG	MANUFACTURER	MODEL	CFM	SP (IN WC)	VELOCITY (FPM)	DIMENSIONS (IN)			MINIMUM INSERTION LOSS RATINGS (dB)								NOTES
						WIDTH	HEIGHT	LENGTH	63	125	250	500	1000	2000	4000	8000	
DS-RTU-1RA	PRICE	RMX72/3E	3900	0.14	1170	24	20	72	9	16	29	44	46	38	25	16	
DS-RTU-1SA	PRICE	RMX72/2D	3900	0.14	1530	20	20	72	6	12	22	39	43	36	23	17	
DS-RTU-2RA	PRICE	RM60/2XD	8100	0.24	1325	40	22	60	9	14	18	25	20	13	11	8	

A2

RADIANT WALL PANEL SCHEDULE									
ID TAG	LOCATION	MANUFACTURER	MODEL	BTUH/LF	FIN TUBE LENGTH	AVERAGE WATER TEMP (F)	GPM	NOTES	
RWP-104-1	LAKE HOUSE	RUNTAL	RF-1	182	7'4"	130	0.13	2	
RWP-104-2	LAKE HOUSE	RUNTAL	RF-1	182	2' 6"	130	0.13	2	
RWP-104-3	LAKE HOUSE	RUNTAL	RF-1	182	10' 8"	130	0.19	1	
RWP-104-4	LAKE HOUSE	RUNTAL	RF-1	182	10' 8"	130	0.19	1	
RWP-105-1	LAKE HOUSE	RUNTAL	RF-1	182	10' 8"	130	0.19	1	
RWP-105-2	LAKE HOUSE	RUNTAL	RF-1	182	10' 6"	130	0.19	1	
RWP-105-3	LAKE HOUSE	RUNTAL	RF-1	182	10' 6"	130	0.19	1	
RWP-105-4	LAKE HOUSE	RUNTAL	RF-1	182	22' 8"	130	0.41	2	
RWP-169-1	LAKE HALL	RUNTAL	RF-1	182	15' 2"	130	0.28	2	
RWP-169-2	LAKE HALL	RUNTAL	RF-1	182	15' 4"	130	0.28	2	
RWP-169-3	LAKE HALL	RUNTAL	RF-1	182	14' 4"	130	0.26	1	
RWP-169-4	LAKE HALL	RUNTAL	RF-1	182	14' 4"	130	0.26	1	
RWP-170-1	LAKE HALL	RUNTAL	RF-1	182	14' 4"	130	0.26	1	
RWP-170-2	LAKE HALL	RUNTAL	RF-1	182	14' 4"	130	0.26	1	
RWP-170-3	LAKE HALL	RUNTAL	RF-1	182	15' 6"	130	0.28	2	
RWP-170-4	LAKE HALL	RUNTAL	RF-1	182	15' 6"	130	0.28	2	
NOTES: 1. PROVIDE WITH 1/2" TALL CUSTOM PEDESTAL TO BE MOUNTED ON STRUCTURAL TUBE. 2. PROVIDE KR30 CANTILEVER BRACKET FOR MOUNTING TO THE MULLIONS.									

BOILER SCHEDULE																						
ID TAG	SERVICE	MANUFACTURER	MODEL	TYPE	REQUIRED OUTPUT (MBH)	BURNER			TURNDOWN RATIO	EWT (F)	LWT (F)	GPM	FLUID	MAX PD (FT HD)	MIN AHRI EFFICIENCY %	MAX WORKING PRESSURE (PSIG)	RELIEF VALVE SET PRESSURE (PSIG)	ELECTRICAL				NOTES
						FUEL TYPE	INPUT (MBH)	GAS PRESSURE (IN W.C.)										VOLTAGE (V/PH/Hz)	FLA	MCA	DISCONNECT	
B-1	LAKE HOUSE	LOCHINVAR	WHB199N	WALL-HUNG	146	NATURAL GAS	199	4.0-14.0	10:1	120	140	19	WATER	1.13	95	80	30	120	3.3	4.2	1-5	
B-2	LAKE HOUSE	LOCHINVAR	WHB199N	WALL-HUNG	146	NATURAL GAS	199	4.0-14.0	10:1	120	140	19	WATER	1.13	95	80	30	120	3.3	4.2	1-5	
B-3	LAKE HALL	LOCHINVAR	WHB285N	WALL-HUNG	215	NATURAL GAS	285	4.0-14.0	10:1	120	140	27	WATER	2.42	95	80	30	120	3.6	4.5	1-5	
B-4	LAKE HALL	LOCHINVAR	WHB285N	WALL-HUNG	215	NATURAL GAS	285	4.0-14.0	10:1	120	140	27	WATER	2.42	95	80	30	120	3.6	4.5	1-5	
NOTES: 1. PROVIDE WITH BOILER PUMPS, SEE PUMP SCHEDULE 2. PROVIDE 30 PSI PRESSURE RELIEF VALVE 3. PROVIDE CONDENSATE NEUTRALIZATION KIT 4. PROVIDE CONCENTRIC VENTING KIT 5. PROVIDE WALL MOUNTING KIT																						

PUMP SCHEDULE																		
ID TAG	SERVICE	MANUFACTURER	MODEL	TYPE	GPM	TDH (FT HD)	OPERATING RPM	FLUID	EFFICIENCY MIN %	SUCTION SIZE (IN)	DISCHARGE SIZE (IN)	MOTOR			ELECTRICAL VOLTAGE (V/PH/Hz)	MOTOR CONTROL		NOTES
												RPM	HP	BHP MAX		STARTER	DRIVE/SPEED CONTROL	
BP-1	LAKE HOUSE B-1	GRUNDFOS	UPXML	IN-LINE	19	16	-	WATER	-	1.5	1.5	-	120 W	-	115/1		ECM	1
BP-2	LAKE HOUSE B-2	GRUNDFOS	UPXML	IN-LINE	19	16	-	WATER	-	1.5	1.5	-	120 W	-	115/1		ECM	1
BP-3	LAKE HALL B-3	GRUNDFOS	UPXML	IN-LINE	27	8	-	WATER	-	2	2	-	120 W	-	115/1		ECM	1
BP-4	LAKE HALL B-4	GRUNDFOS	UPXML	IN-LINE	27	8	-	WATER	-	1.61	1.61	-	120 W	-	115/1		ECM	1
HWP-1	LAKE HOUSE	B&G	Ecocirc XL 65-130	IN-LINE	20	40	2777	WATER	31.8	1.61	1.61	2777	1	0.634	208/1/60		ECM	
HWP-2	LAKE HOUSE	B&G	Ecocirc XL 65-130	IN-LINE	20	40	2777	WATER	31.8	1.61	1.61	2777	1	0.634	208/1/60		ECM	
HWP-3	LAKE HALL	B&G	Ecocirc XL 65-130	IN-LINE	30	45	2960	WATER	39.6	1.61	1.61	2960	1	0.86	208/1/60		ECM	
HWP-4	LAKE HALL	B&G	Ecocirc XL 65-130	IN-LINE	30	45	2960	WATER	39.6	1.61	1.61	2960	1	0.86	208/1/60		ECM	
NOTES: 1. CIRCULATOR PUMPS PROVIDED WITH BOILER BY MANUFACTURER.																		

Van Buren Charter Township

Van Buren Township, MI

The Lakeside Park

fishbeck

Engineers | Architects | Scientists | Constructors

REVISIONS

10/27/2022	A2	ADDENDUM NO. 2
------------	----	----------------

10/12/2026	BIDS & PERMIT
09/21/2026	CD PEER REVIEW
09/09/2026	CD TEAM REVIEW
08/10/2026	CD 50% PROGRESS
08/22/2026	DD OWNER REVIEW
06/15/2026	DD PEER REVIEW
06/08/2026	DD 90 % PROGRESS
05/18/2026	DD 90 % PROGRESS
02/23/2026	SD OWNER REVIEW
02/13/2026	SD PEER REVIEW
02/09/2026	SD PROGRESS REVIEW

Drawn By CUHLIG

Designer CUHLIG

Reviewer GLOUIS

Manager CKRETOVIC

Hard copy is intended to be 24"x36" when plotted. Scale(s) indicated and graphic quality may not be accurate for any other size.

PROJECT NO.

2500281

SHEET NO.

H702

©Copyright 2026
All Rights Reserved

LUMINAIRE SCHEDULE												
MARK	DESCRIPTION	BASIS OF DESIGN MFR.	CATALOG NO.	APPROVED EQUAL MFR. #1	APPROVED EQUAL MFR. #2	LUMINAIRE DATA					DIMMIN G	REMARKS
						VOLTAGE	LOAD	LUMENS	CCT	CRI		
A1	2x2 RECESSED LED FLAT PANEL	LITHONIA	CPANL 2X2 AL01 SSW7M4	METALLUX	ELITE LIGHTING	120 V	41 VA	4,400 lm	4000 K	80	0-10V	
A1E	2x2 RECESSED LED FLAT PANEL WITH EMERGENCY BATTERY BACK-UP	LITHONIA	CPANL 2X2 AL01 SSW7M4 ILPCP10A	METALLUX	ELITE LIGHTING	120 V	41 VA	4,400 lm	4000 K	80	0-10V	INTEGRAL EMERGENCY BATTERY
A1S	2x2 RECESSED LED FLAT PANEL EXCEPT WITH SURFACE DRYWALL GRID ADAPTER	LITHONIA	CPANL 2X2 AL01 SSW7M4 DGA22	METALLUX	ELITE LIGHTING	120 V	41 VA	4,400 lm	4000 K	80	0-10V	SURFACE DRYWALL GRID ADAPTER
B	DECORATIVE PENDANT MOUNTED LUMINAIRE. 17/75"H x 25"W, 5" ROUND CANOPY, (40 C11, 12W CANDELABRA BASED LAMPS, 6'0" CHAIN. MOUNT WITH BOTTOM AT 7'6" AFF	VISUAL COMFORT & CO.	AFN 5173G-CG	(NONE)		120 V	8 VA				0-10V	LUMINAIRE FINISH SHALL BE METALLIC SILVER WITH CHROME SUPPORT ARMS
C4	4 INCH x 4" RECESSED LINEAR FIXTURE.	FINELITE	HP-4-R-D-10"-S-840-F-96LG-120-SC-FC-10%-C1-FE-SW	AXIS LIGHTING	3G LIGHTING	120 V	35 VA	4,440 lm	4000 K	80	0-10V	FLUSH DIFFUSER; 15/16" T-BAR
C4E	4 INCH x 4" RECESSED LINEAR FIXTURE WITH BATTERY BACK-UP.	FINELITE	HP-4-R-D-10"-S-840-F-96LG-120-SC-FC-10%-C1-FE-SW-LGD10W	AXIS LIGHTING	3G LIGHTING	120 V	35 VA	4,440 lm	4000 K	80	0-10V	10W, 90-MIN. BATTERY BACK-UP
C4F	4 INCH x 4" RECESSED LINEAR FIXTURE, FLANGED FOR GYP CEILING.	FINELITE	HP-4-R-D-10"-S-840-F-96LG-120-SC-FC-10%-VF-FE-SW	AXIS LIGHTING	3G LIGHTING	120 V	35 VA	4,440 lm	4000 K	80	0-10V	VISIBLE FLANGE FOR GYP CEILING
C10	4 INCH x 10" RECESSED LINEAR FIXTURE.	FINELITE	HP-4-R-D-10"-B-840-F-96LG-120-SC-FC-10%-C1-FE-SW	AXIS LIGHTING	3G LIGHTING	120 V	93 VA	11,000 lm	4000 K	80	0-10V	BOOSTED OUTPUT
D1	4" RECESSED LED DOWNLIGHT WIDE DISTRIBUTION	GOTHAM	IV04-D-15LM-40K-80CRI-MWD-MIN1-MVOLT-ZT-NCH-P-AR-LSS-F	USA1	3G LIGHTING	120 V	30 VA	2,732 lm	4000 K	80	0-10V	
D1E	4" RECESSED LED DOWNLIGHT WITH WIDE DISTRIBUTION ADN INTEGRAL EMERGENCY BATTERY PACK	GOTHAM	IV04-D-30LM-40K-80CRIWD-MIN1-MVOLT-ZT-E10W-NCH-P-AR-LSS-F	USA1	3G LIGHTING	120 V	30 VA	1,486 lm	4000 K	80	0-10V	INTEGRAL EMERGENCY BATTERY
E1	4" RECESSED LED DOWNLIGHT	METEOR	RS4N-20-408-120-STV-4S-WHT	USA1	3G LIGHTING	120 V	20 VA	2,080 lm	4000 K	85	0-10V	45" BEAM; WHITE TRIM
E1E	4" RECESSED LED DOWNLIGHT WITH REMOTE EMERGENCY BATTERY PACK	METEOR	RS4N-20-408-120-STV-4S-WHT + EMP	USA1	3G LIGHTING	120 V	20 VA	2,080 lm	4000 K	85	0-10V	REMOTE EMERGENCY PACK; 1,720 LM EMERGENCY OUTPUT
EM	MULLION MOUNT EMERGENCY LIGHT WITH REMOTE POWER SUPPLY	LIGHTLALARMS	LAMM-SP	(NONE)	(NONE)		16 VA	900 lm	4000 K			ROUTE WIRING WITHIN MULLION.
F2	23" x 4.75" x 4.5" D WITH A 4.5" x 7" BACKPLATE. BRONZE FINISH, WHITE GLASS DIFFUSER, VANITY LIGHT, MOUNTED HORIZONTALLY, EQUIP WITH (2) 60W T-10 EQUIVALENT LAMPS	VISUAL COMFORT & CO.	S-2164B2-WG	(NONE)	(NONE)	120 V	16 VA	800 lm	4000 K	80	NO	MOUNT AT 7'-0" AFF
F5	5" SURFACE WALL MOUNTED VANITY LIGHT	VISA	CV1718-L40(K)L-MVOLT-GSILV	AXIS LIGHTING	CAMMAN LIGHTING	120 V	27 VA	2,000 lm	4000 K	80	0-10V	MOUNT AT 7'-0" AFF
G2	RECESSED WALK-OVER LED IN-GRADE COLUMN UPLIGHT, 90"V x 15"H BI-SYMMETRIC OPTIC, FLUSH TRIM	LUMENPULSE	LBIL-WO-120/277-30K-90x15-CL-DIM-FLN-SSB-RBO-ASL-HRS-UL	MEYER LIGHTING	KIM LIGHTING	120 V	60 VA					
HR	RECESSED LED LIGHT INTEGRATED INTO THE HANDRAIL POSTS AND ASSOCIATED WIRING AND POWER SUPPLIES AND IP67 ENCLOSURES.	MINIMIS	PX-MP-30-BK-NOKIT-PKMP1630 (SIX)-10V	(NONE)	(NONE)	120 V	2 VA	19 lm	3000 K	90	0-10V	44444
J1	18" DECORATIVE LED DRUM, SURFACE MOUNTED	LUMETTA	SM5188/F11/D61/L411	SHAPER	CAMMAN LIGHTING	120 V	21 VA	1,782 lm	4000 K	90	0-10V	WHITE FINISH / DIFFUSER
K1	24" DECORATIVE CHANDELIER	MOOOIE	HERACLEUM III THE BIG O	SHAPER	CORONET LED	120 V	32 VA	2,940 lm	4000 K	90	0-10V	ARO PENDANT; MATTE WHITE; FIELD-ADJUSTABLE SUSPENSION; COORD. WITH ARCHITECT
L	ILLUMINATED MIRROR	BRADLEY	7B1-20-0-24-36	(NONE)	(NONE)	120 V	37 VA	3,650 lm	3000 K	90		
N2	18"L x 2.55"D x 1.07"H UNDERCABINET LIGHT	JUNO	U02S 18M SSW5 90CRI WH M6	LITELINE	ELITE LIGHTING	120 V	13 VA	1,100 lm	4000 K	90		
OB1	13" LED SITE LIGHT COLUMN, ROUND PROFILE, DIFFUSED LENS	HESS	SE4000C-F-13-30K-DIM-UNV-BL			120 V	37 VA	3,738 lm	3000 K	80	0-10V	DIRECT WIRE; SET SELECTABLE COT TO 4000K
OB2	LED BOLLARD, SHIELDED 180" DISTRIBUTION	BEGA	77 753_K3	WE-EF	TARGETTI USA	120 V	10 VA	411 lm	3000 K	80	0-10V	39-3/8" HIGH; ONE-SIDED DISTRIBUTION
PAC	ILLUMINATED PEBBLE, STYLE "A" IN "CITRINE" COLOR	ANDLight	PEBBLE-CW-A-CL-DWP010-120	(NOTE)	(NONE)	120 V	9 VA	622 lm	2700 K	90	0-10V	39-3/8" HIGH; ONE-SIDED DISTRIBUTION
PAS	ILLUMINATED PEBBLE, STYLE "A" IN "SLATE" COLOR	ANDLight	PEBBLE-CW-A-SL-DWP010-120	(NOTE)	(NONE)	120 V	9 VA	622 lm	2700 K	90	0-10V	
PBC	ILLUMINATED PEBBLE, STYLE "B" IN "CITRINE" COLOR	ANDLight	PEBBLE-CW-B-CL-DWP010-120	(NONE)	(NONE)	120 V	9 VA	622 lm	2700 K	90	0-10V	
PBP	ILLUMINATED PEBBLE, STYLE "B" IN "PEARL" COLOR	ANDLight	PEBBLE-CW-B-PL-DWP010-120	(NONE)	(NONE)	120 V	9 VA	622 lm	2700 K	90	0-10V	
PCC	ILLUMINATED PEBBLE, STYLE "C" IN "CITRINE" COLOR	ANDLight	PEBBLE-CW-C-CL-DWP010-120	(NONE)	(NONE)	120 V	9 VA	622 lm	2700 K	90	0-10V	
PCP	ILLUMINATED PEBBLE, STYLE "C" IN "PEARL" COLOR	ANDLight	PEBBLE-CW-C-PL-DWP010-120	(NONE)	(NONE)	120 V	9 VA	622 lm	2700 K	90	0-10V	
PDP	ILLUMINATED PEBBLE, STYLE "D" IN "PEARL" COLOR	ANDLight	PEBBLE-CW-D-PL-DWP010-120	(NONE)	(NONE)	120 V	9 VA	622 lm	2700 K	90	0-10V	
PDS	ILLUMINATED PEBBLE, STYLE "D" IN "SLATE" COLOR	ANDLight	PEBBLE-CW-D-SL-DWP010-120	(NONE)	(NONE)	120 V	9 VA	622 lm	2700 K	90	0-10V	
Q1	52" BOLA FELT	PABLO	BOLA FELT 24	(NONE)	(NONE)	120 V	20 VA	800 lm	2700 K	95	0-10V	8.9 FT. FIELD CUTTABLE CABLE. COORDINATE LENGTH WITH THE ARCHITECT.
Q2	42" BOLA FELT	PABLO	BOLA FELT 32	(NONE)	(NONE)	120 V	12 VA	1,625 lm	2700 K	95	0-10V	8.9 FT. FIELD CUTTABLE CABLE. COORDINATE LENGTH WITH THE ARCHITECT.
Q3	32" BOLA FELT	PABLO	BOLA FELT 42	(NONE)	(NONE)	120 V	12 VA	1,625 lm	2700 K	95	0-10V	8.9 FT. FIELD CUTTABLE CABLE. COORDINATE LENGTH WITH THE ARCHITECT.
Q4	24 BOLA FELT	PABLO	BOLA FELT 52	(NONE)	(NONE)	120 V	12 VA	1,625 lm	2700 K	95	0-10V	8.9 FT. FIELD CUTTABLE CABLE. COORDINATE LENGTH WITH THE ARCHITECT.
R1	4"x8" LINEAR	LUMENPULSE	LCM2RO-UL-120-12-27-TAW-FR	(NONE)	(NONE)		3 VA	405 lm	2700 K	80	0-10V	PROVIDE DIGITAL DATA BRIDGE AND ALL CONNECTORS, CORDS FOR A COMPLETE SYSTEM. ADJUST R1 AND R4 LUMINAIRES FOR OPTIMAL PERFORMANCE. OVERLAP FIXTURES AS REQUIRED TO ACCOMMODATE COVE LENGTHS.
R4	4"x8" LINEAR	LUMENPULSE	LCM2RO-UL-1200-48-27-TAW-FR	(NONE)	(NONE)		12 VA	1,214 lm	2700 K	80	0-10V	
SK1	LED LIGHTING AT SKYRING.	LUMENPULSE	LPM-CR-UL-120-277-36-22-MRGBA-10x30x-CL-NF-LT-VRN-SM-XD-BK-NA SERIES	(NONE)	(NONE)	120 V	66 VA	2,610 lm	4100 K	90	0-10V	PROVIDE ALL ACCESSORIES, JUMPERS, MOUNTING BRACKETS FOR A COMPLETE AND FUNCTIONING SYSTEM.
TC	6" RECESSED LINEAR LED FIXTURE	FINELITE	HP-4-R-D-6"-B-840-F-96LG-120-SC-FC-10%-C1-FE	AXIS LIGHTING	3G LIGHTING	120 V	27 VA	3,420 lm	4000 K	80	0-10V	FLUSH DIFFUSER
TCE	6" RECESSED LINEAR LED FIXTURE	FINELITE	HP-4-R-D-6"-B-840-F-96LG-120-SC-FC-10%-C1-FE-LGD10W	AXIS LIGHTING	3G LIGHTING	120 V	27 VA	3,420 lm	4000 K	80	0-10V	FLUSH DIFFUSER AND 4 FOOT SECTION WITH 10W BATTERY BACK-UP
U1	4" SURACE MOUNTED LED STRIP FIXTURE	LITHONIA	CLX-L48-4000LM-SEF-RDL-MVOLT-40K-80CRI-WH	COLUMBIA	LSI INDUSTRIES	120 V	23 VA	4,237 lm	4000 K	80	0-10V	-
U1E	4" SURFACE MOUNTED LED STRIP FIXTURE WITH INTEGRAL EMERGENCY BATTERY PACK	LITHONIA	CLX-L48-4000LM-SEF-RDL-MVOLT-40K-80CRI-E10W-WH-THCL-WH	COLUMBIA	LSI INDUSTRIES	120 V	23 VA	4,237 lm	4000 K	80	0-10V	INTEGRAL EMERGENCY BATTERY
V	4" STRIP LIGHT (0.2"W x 0.06"H AND LENSED CHANNEL (0.31"W x 0.31"H) WITH END CAPS AND METAL MOUNTING CLIPS, 3.58" OF TAPE IN A 4" CHANNEL. TO BE INTEGRATED INTO WALL TO ILLUMINATE A TRANSLUCENT TILE	OMNILIGHT:	TRUM-4100-HO-LPCFR-AEC-2-MM / OCH-134	COLUMBIA	(NONE)	120 V	1 VA	95 lm	4100 K	90	0-10V	
W8	4 INCH x 8" RECESSED LINEAR WALL-WASH FIXTURE	FINELITE	HP-4-R-WW-D-8"-S-840-K-SSA-120-SC-FC-10%-C1-FE-SW	AXIS LIGHTING	CORONET LED	120 V	18 VA	3,220 lm	4000 K	80	0-10V	WALL WASH
WP1	LED FULL-CUTOFF WALL PACK	LITHONIA	WPX1 LED P2 30K MVOLT DDBXD-E14WC	LUMARK	LSI INDUSTRIES	120 V	24 VA	2,478 lm	3000 K	70	0-10V	TYPE III SHORT DISTRIBUTION; DARK BRONZE; WET LOCATION; IP66
X1	SINGLE FACE LED EXIT SIGN, BACK MOUNTED, SELF POWERED WITH INTEGRAL BATTERY.	SURE-LITES	CX 7 1 SD	LITHONIA	LIGHTALARMS	120 V	6 VA				--	CHEVRONS AS INDICATED ON PLANS
X2	DOUBLE FACE LED EXIT SIGN, CEILING MOUNT, SELF POWERED WITH INTEGRAL BATTERY.	SURE-LITES	CX 7 2 SD	LITHONIA	LIGHTALARMS	120 V	8 VA				--	CHEVRONS AS INDICATED ON PLANS
X3	SINGLE FACE LED EXIT SIGN, CEILING MOUNTED, SELF POWERED WITH INTEGRAL BATTERY.	SURE-LITES	CX 7 1 SD	LITHONIA	LIGHTALARMS	120 V	6 VA				--	CHEVRONS AS INDICATED ON PLANS
X4	SINGLE FACE LED EXIT SIGN, END MOUNTED - LEFT, SELF POWERED WITH INTEGRAL BATTERY.	SURE LITES	CX 7 1 SD	LITHONIA	LIGHTALARMS	120 V	6 VA				--	CHEVRONS AS INDICATED ON PLANS
X5	SINGLE FACE LED EXIT SIGN, END MOUNTED - RIGHT, SELF POWERED WITH INTEGRAL BATTERY.	SURE LITES	CX 7 1 SD	LITHONIA	LIGHTALARMS	120 V	6 VA				--	CHEVRONS AS INDICATED ON PLANS

REVISIONS		
10/27/2026	A2	ADDENDUM NO. 2

10/12/2026	BIDS & PERMIT
09/21/2026	CD PEER REVIEW
09/09/2026	CD TEAM REVIEW
08/10/2026	CD 50% PROGRESS
08/22/2026	DD OWNER REVIEW
06/15/2026	DD PEER REVIEW
06/08/2026	DD 90 % PROGRESS
05/18/2026	DD 90 % PROGRESS
02/23/2026	SD OWNER REVIEW
02/13/2026	SD PEER REVIEW
02/09/2026	SD PROGRESS REVIEW


Drawn By	JMILOCH
Designer	JMILOCH
Reviewer	STKAM
Manager	CKRETOVIC

Hard copy is intended to be 24"x36" when plotted. Scale(s) indicated and graphic quality may not be accurate for any other size.


PROJECT NO.
2500281

SHEET NO.


E003

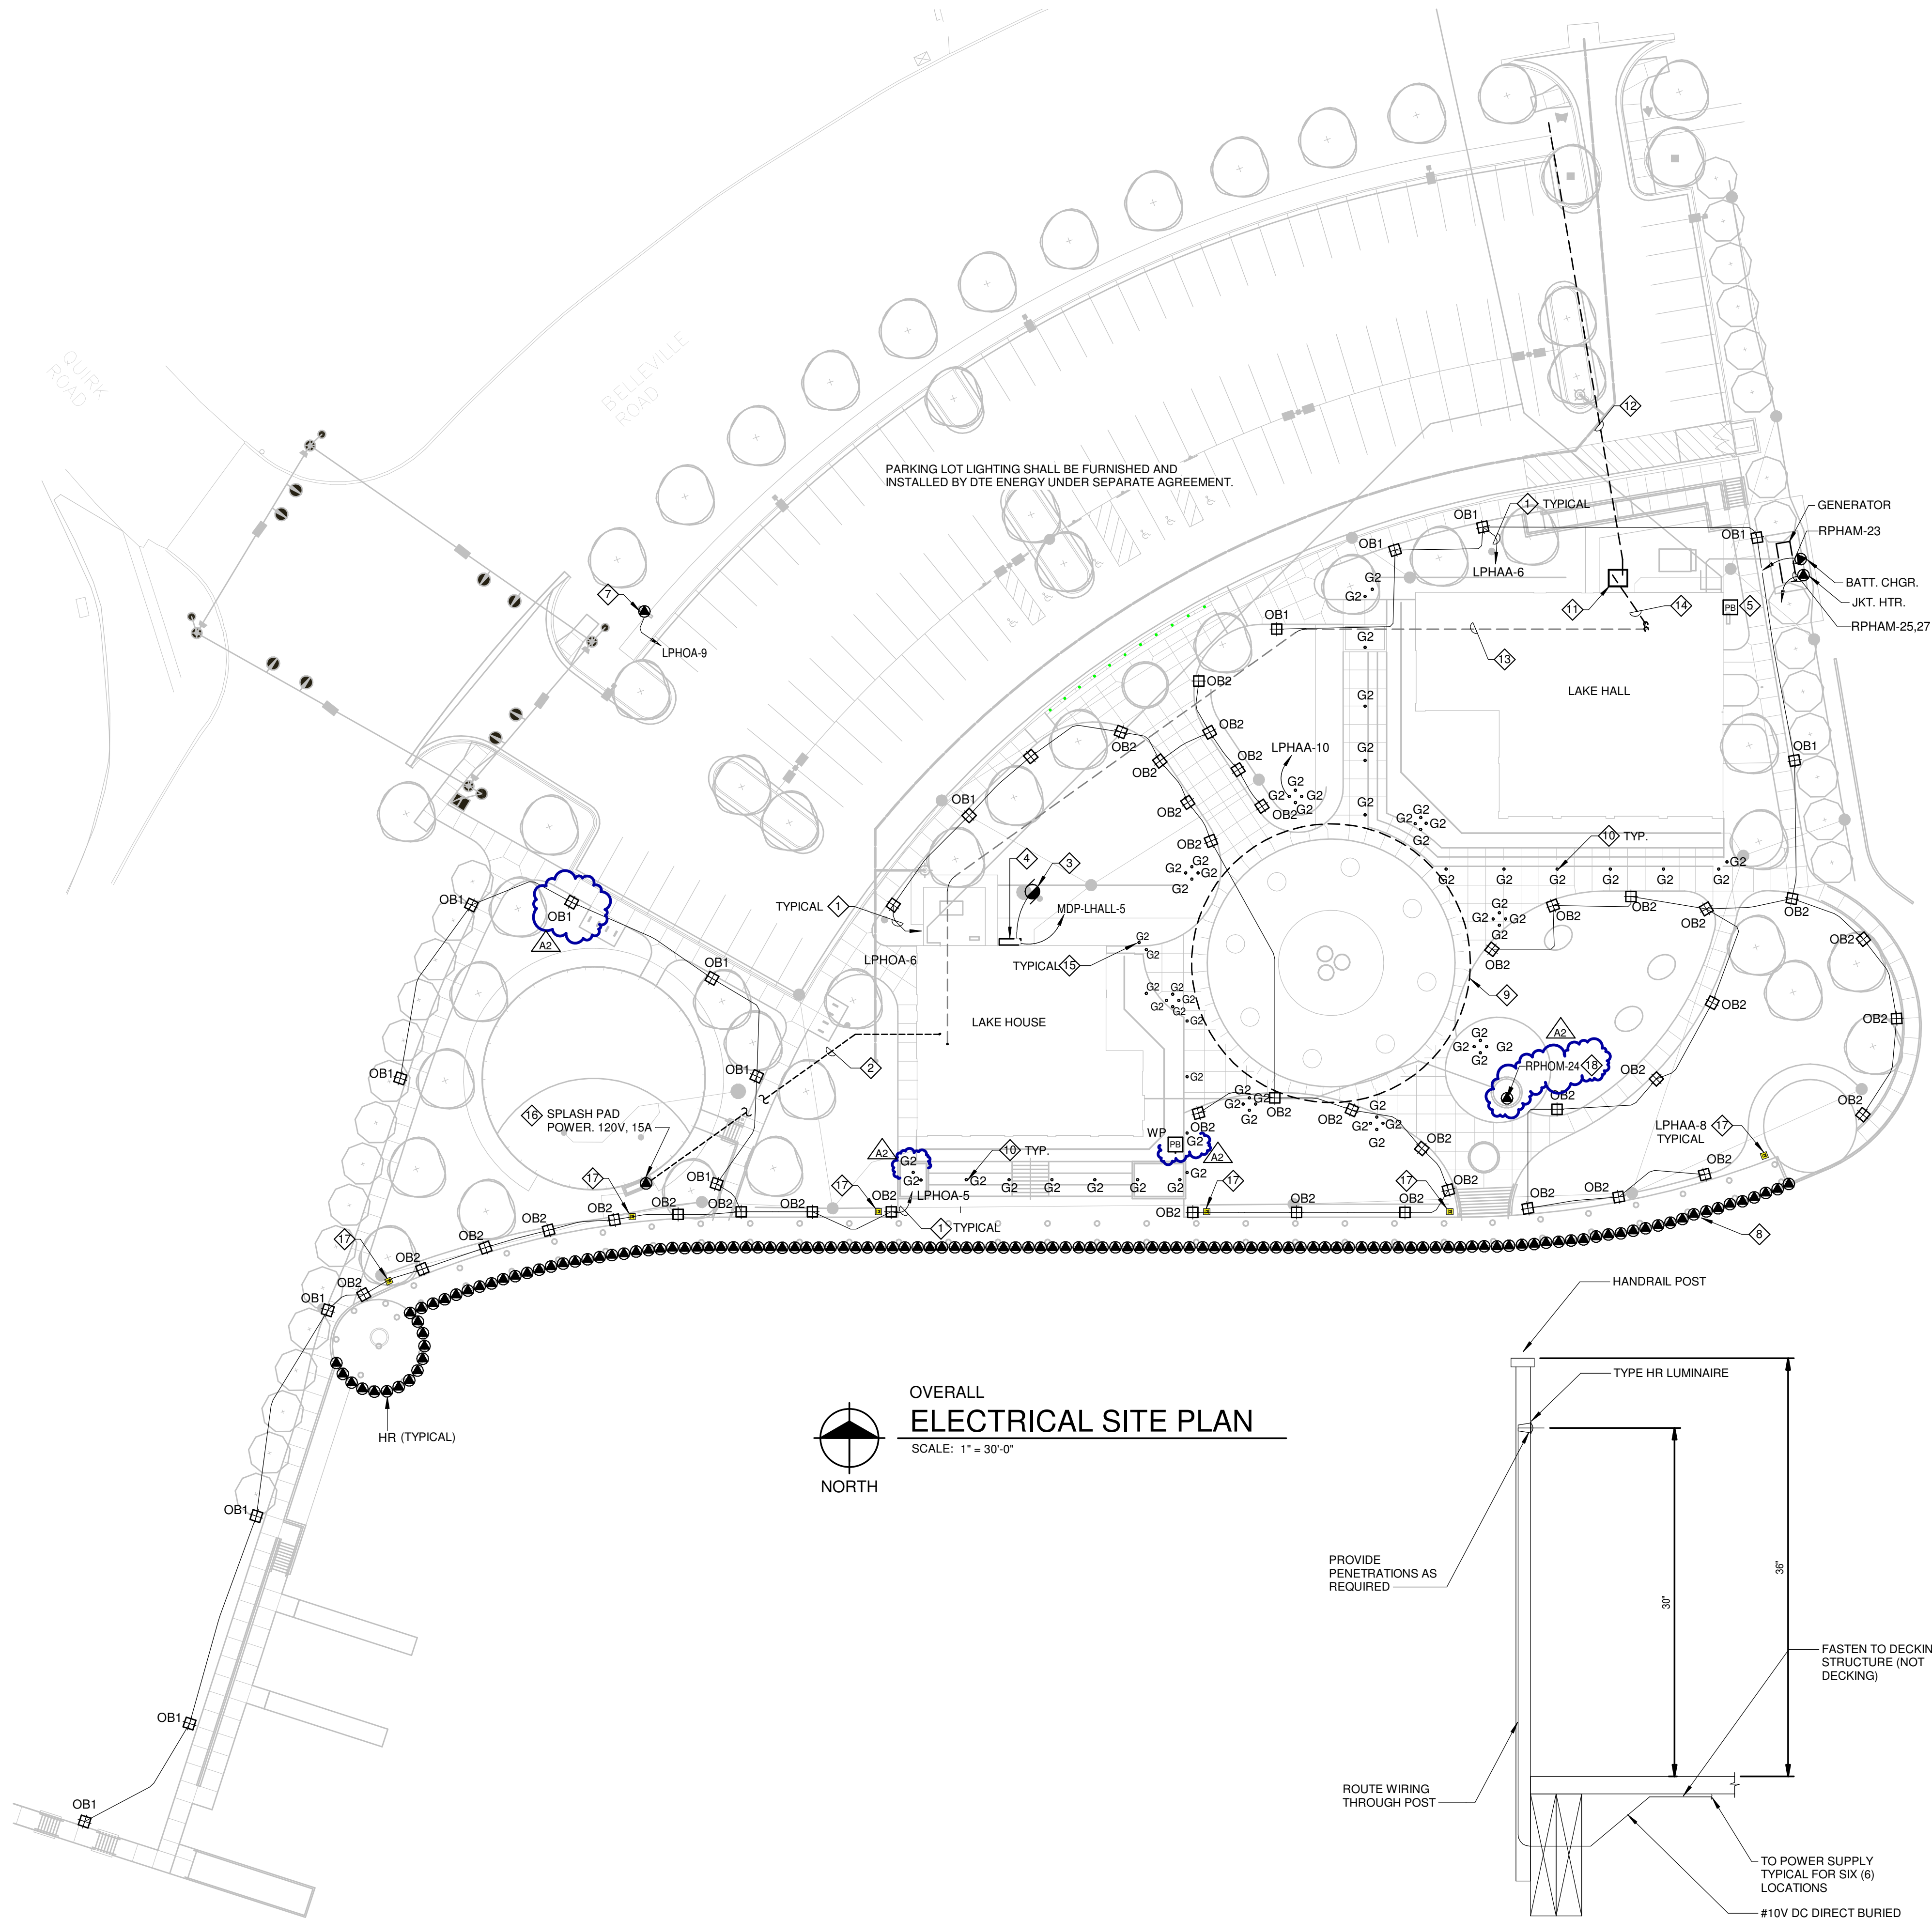

OVERALL
ELECTRICAL SITE PLAN
SCALE: 1" = 30'-0"

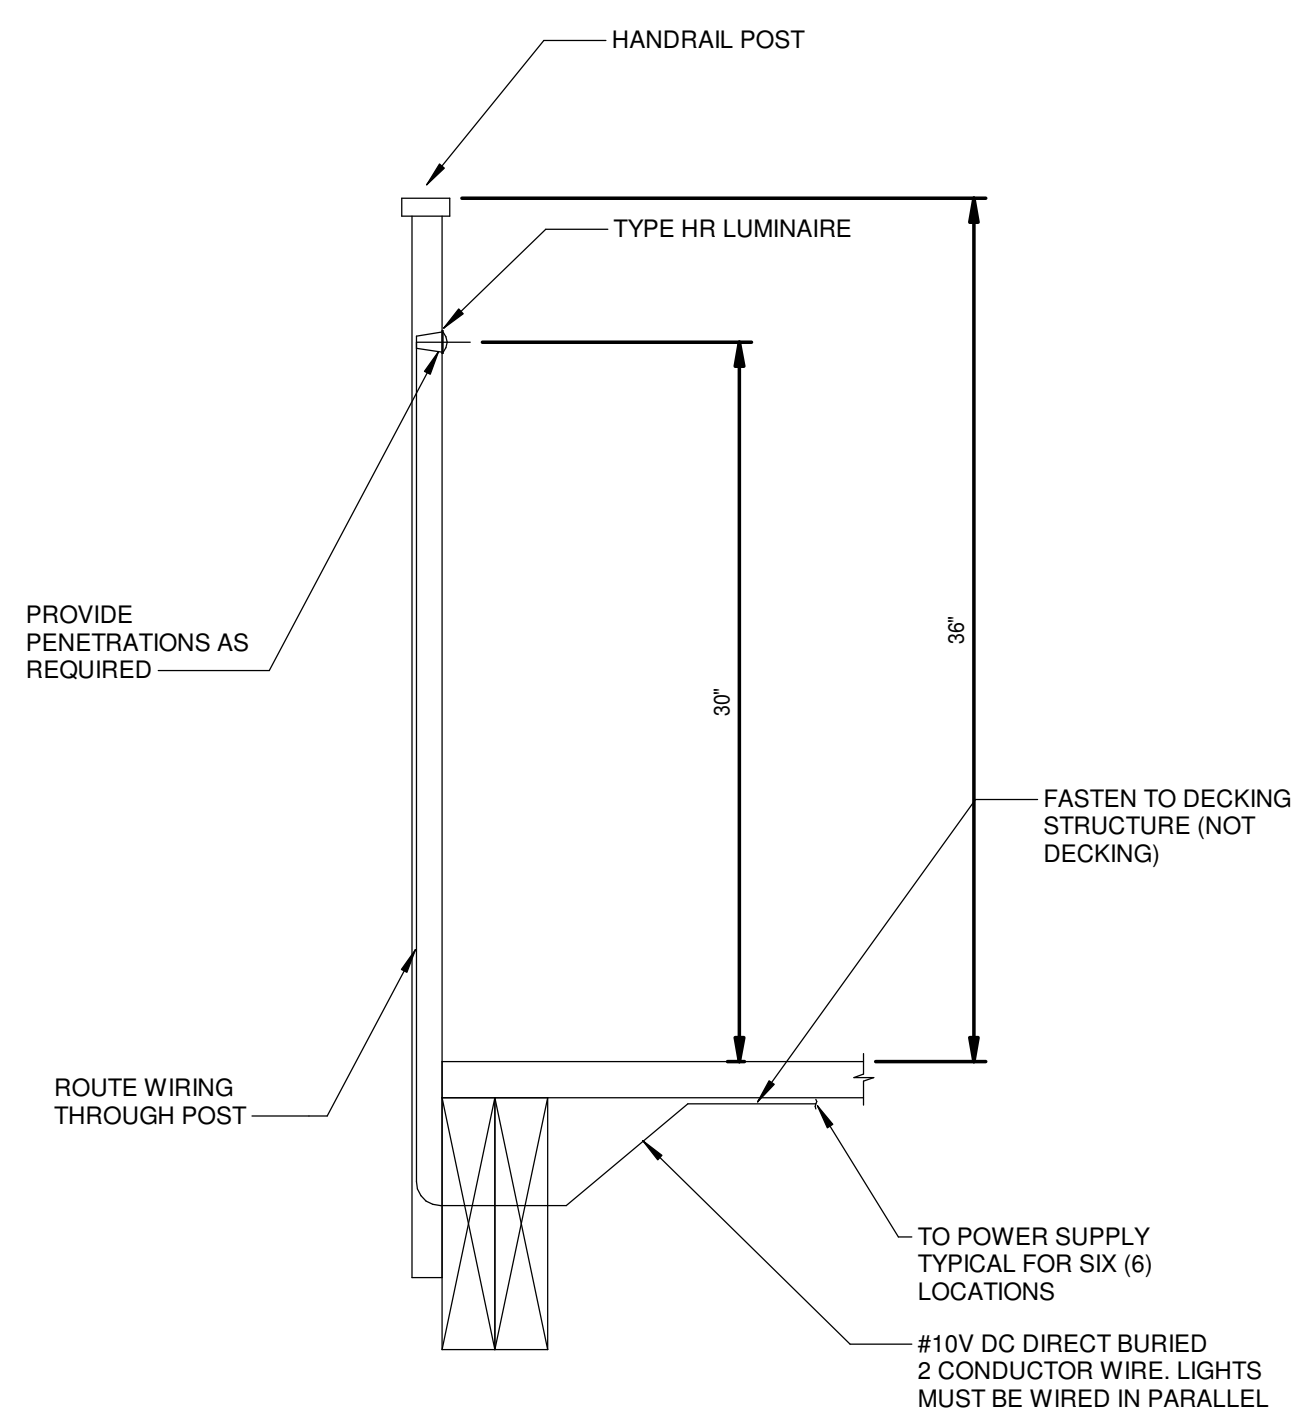


HANDRAIL LIGHTING (TYPE HR) DETAIL
SCALE: 1 1/2" = 1'-0"

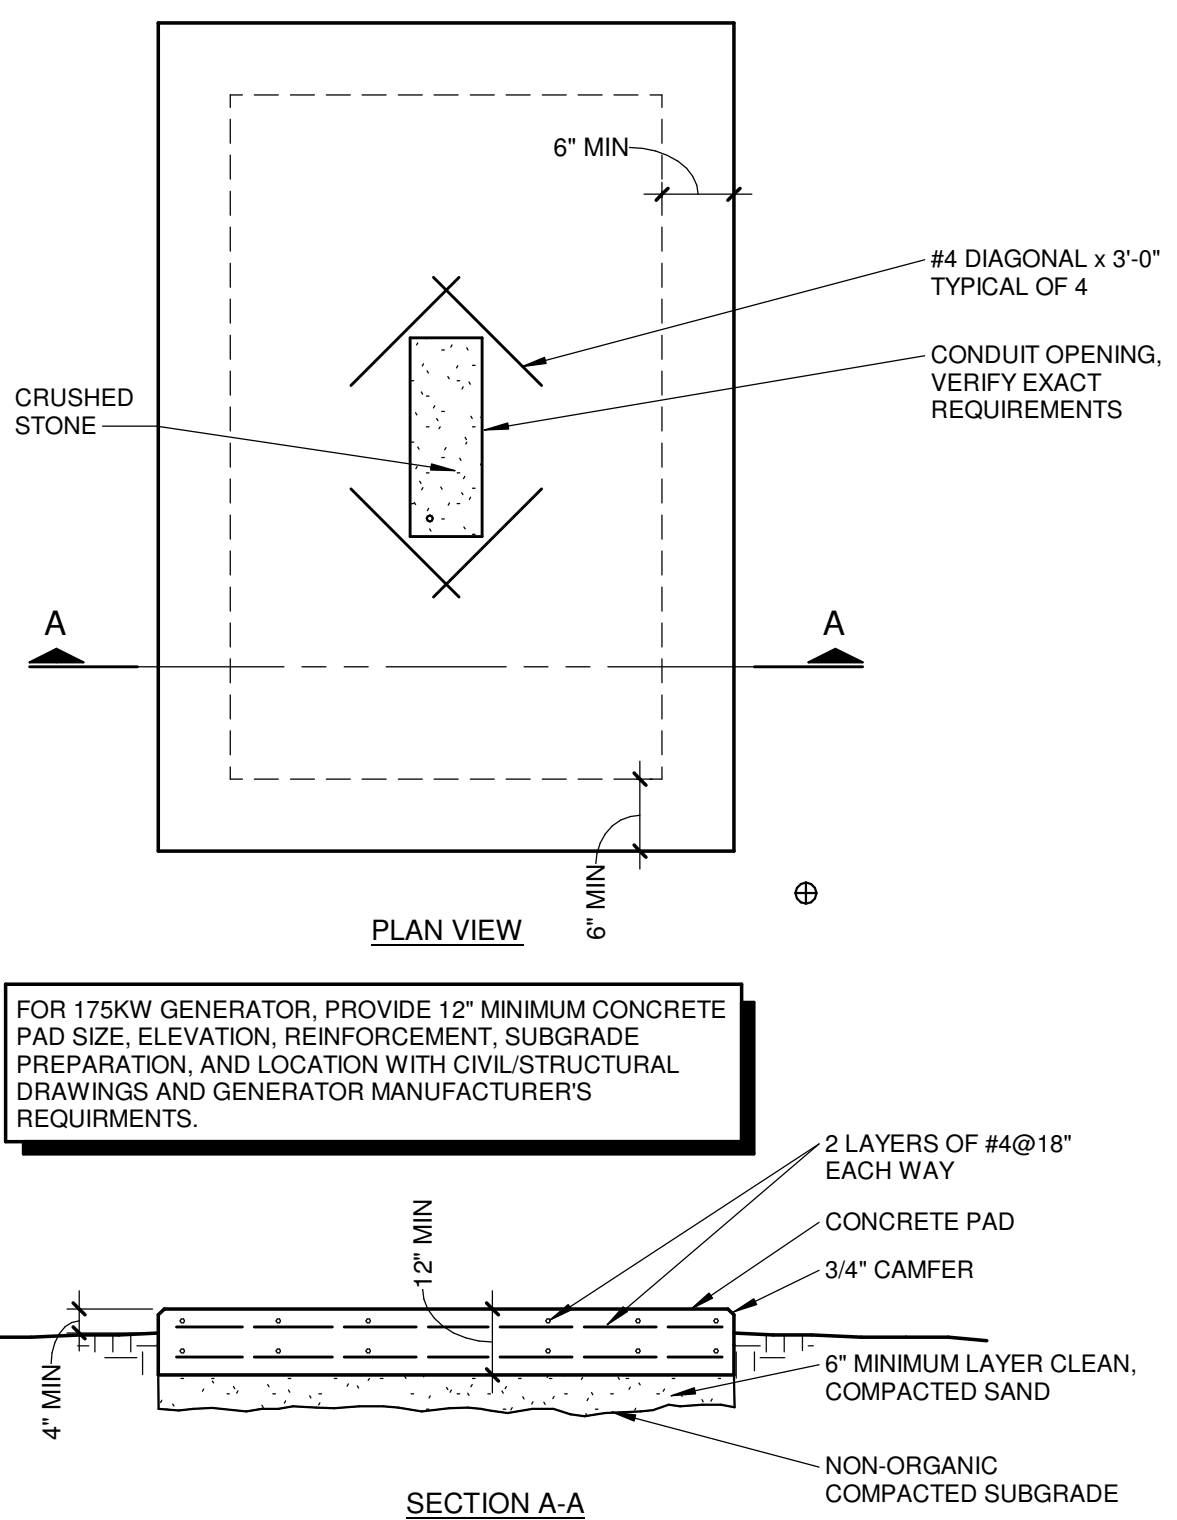

GENERATOR PAD DETAIL
NO SCALE

KEY PLAN

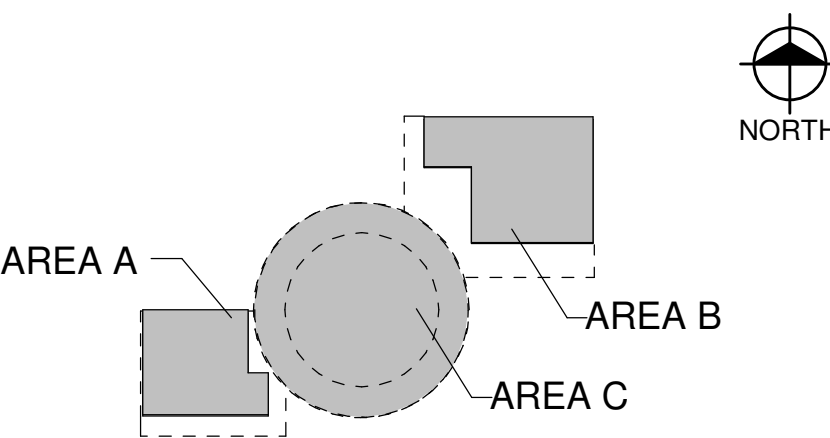

GENERAL NOTES

- CONDUIT AND WIRE SHALL BE 2#12, #12G, 3/4"C. UNLESS NOTED OTHERWISE.
- REFER TO DRAWING C102 FOR EXISTING LIGHT POLE REMOVAL REQUIREMENTS.

KEY NOTES

- POLE LIGHTING BRANCH CIRCUITS SHALL BE 2#8 & #10G IN 1"C. U.G. UNLESS NOTED OTHERWISE.
- ELECTRICAL FEEDER FOR THE SPLASH PAD EQUIPMENT. 2#8, #8 GRD, 1"C. TO 1P15A CIRCUIT BREAKER IN PANEL RP-HOM.
- GPS-1 SANITARY GRINDER PUMP STATION, APPROXIMATE LOCATION SHOWN, COORDINATE FINAL LOCATION WITH CIVIL.
- GPS-1 CONTROL PANEL. REFER TO SHEETS E301 AND E401 FOR ADDITIONAL INFORMATION.
- PROVIDE NEMA 3R REMOTE GENERATOR E-STOP STATION WITHIN SIGHT OF GENERATOR. COORDINATE CONNECTION WITH GENERATOR MANUFACTURER.
- NOT USED.
- PROVIDE (2) 2" CONDUITS FROM ELECTRICAL ROOM 107 IN LAKE HOUSE BUILDING TO MARQUEE SIGN. CAP AND MARK ONE CONDUIT AS SPARE. IN SECOND CONDUIT, PROVIDE 2#6 AND #6G. COORDINATE FINAL POWER AND CONNECTION REQUIREMENTS WITH SIGNAGE SHOP DRAWINGS AND OWNER PRIOR TO ROUGH-IN.
- PROVIDE COMPLETE 12VDC LED HANDRAIL LIGHTING SYSTEM, INCLUDING LUMINAIRES, CLASS II POWER SUPPLIES, WEATHERPROOF ENCLOSURES, WIRING, AND ACCESSORIES. COORDINATE QUANTITY, SPACING, MOUNTING, AND POWER SUPPLY LOCATIONS WITH HANDRAIL SHOP DRAWINGS AND MANUFACTURERS REQUIREMENTS. HANDRAILS ARE APPROXIMATELY 40" ON CENTER. REFER TO THE DETAIL ON THIS DRAWING.
- LED PERIMETER LIGHTING TO GRAZE THE UNDERSIDE OF THE SKYRING. ANTICIPATE A RADIUS OF 283'0". LUMINAIRES SHALL BE TYPE "SK1". REFER TO THE FIXTURE SCHEDULE. DRIVERS SHALL BE MOUNTED IN THE STRUCTURE, HIDDEN FROM VIEW.
- UPLIGHTS TO ILLUMINATE THE COLUMNS, REFER TO E101 AND E102 FOR MORE INFORMATION.
- DTE PAD MOUNTED TRANSFORMER. VERIFY CONDUIT ROUTING WITH THE SERVICE PLANNER, PRIOR TO STARTING CONSTRUCTION. REFER TO THE DTE DETAILS ON E603.
- (2) 5" SCHEDULE 40 PVC CONDUITS TO THE PROPERTY LINE WITH PULL STRINGS AT THE LOCATION DETERMINED BY THE DTE SERVICE PLANNER.
- FEEDER TO LAKE HOUSE. REFER TO E401 FOR FURTHER INFORMATION.
- SERVICE ENTRANCE CONDUCTORS. REFER TO E401 FOR FURTHER INFORMATION.
- REFER TO E101 AND E102 FOR COLUMN UPLIGHT CIRCUITING.
- FOR THE SPLASH PAD, THE ELECTRIC CONTRACTOR SHALL OBTAIN AN ELECTRICAL PERMIT FOR THE SPLASH PAD AND PERFORM THE FINAL HOOK UP AND BONDING LOOP OF FEATURES AND CONCRETE. . REFER TO NEC ARTICAL 680.
- QUAZITE, 24"X 24" X 12"D WITH TIER 22 COVER #B16242412A FOR TYPE HR POWER SUPPLIES AND TERMINAL STRIPS. SERVE FROM CIRCUIT INDICATED WITH 2#8#6G, 1"C. VIA THE EMERGENCY PUSHBUTTON ON THE LAKEHOUSE AND THE SWITCH LOCATED IN AT THE RECEPTION DESK.

Van Buren Charter Township

Van Buren Township, MI

The Lakeside Park



Engineers | Architects | Scientists | Constructors

REVISIONS		
10/27/2026	A2	ADDENDUM NO. 2

10/12/2026	BIDS & PERMIT
09/21/2026	CD PEER REVIEW
09/09/2026	CD TEAM REVIEW
08/10/2026	CD 50% PROGRESS
06/22/2026	DD OWNER REVIEW
06/15/2026	DD PEER REVIEW
06/08/2026	DD 90% PROGRESS
05/18/2026	DD 90% PROGRESS
02/23/2026	SD OWNER REVIEW
02/13/2026	SD PEER REVIEW
02/09/2026	SD PROGRESS REVIEW


Drawn By	JMILOCH
Designer	JMILOCH
Reviewer	STKAM
Manager	CKRETOVIC

Hard copy is intended to be 24"x36" when plotted. Scale(s) indicated and graphic quality may not be accurate for any other size.

PROJECT NO.	2500281
SHEET NO.	

E010

PLOT INFO: 10/27/2026 11:13:12 AM Autodesk Docs://2500281 - Van Buren Twp Lake House/2026_E_2500281.rvt

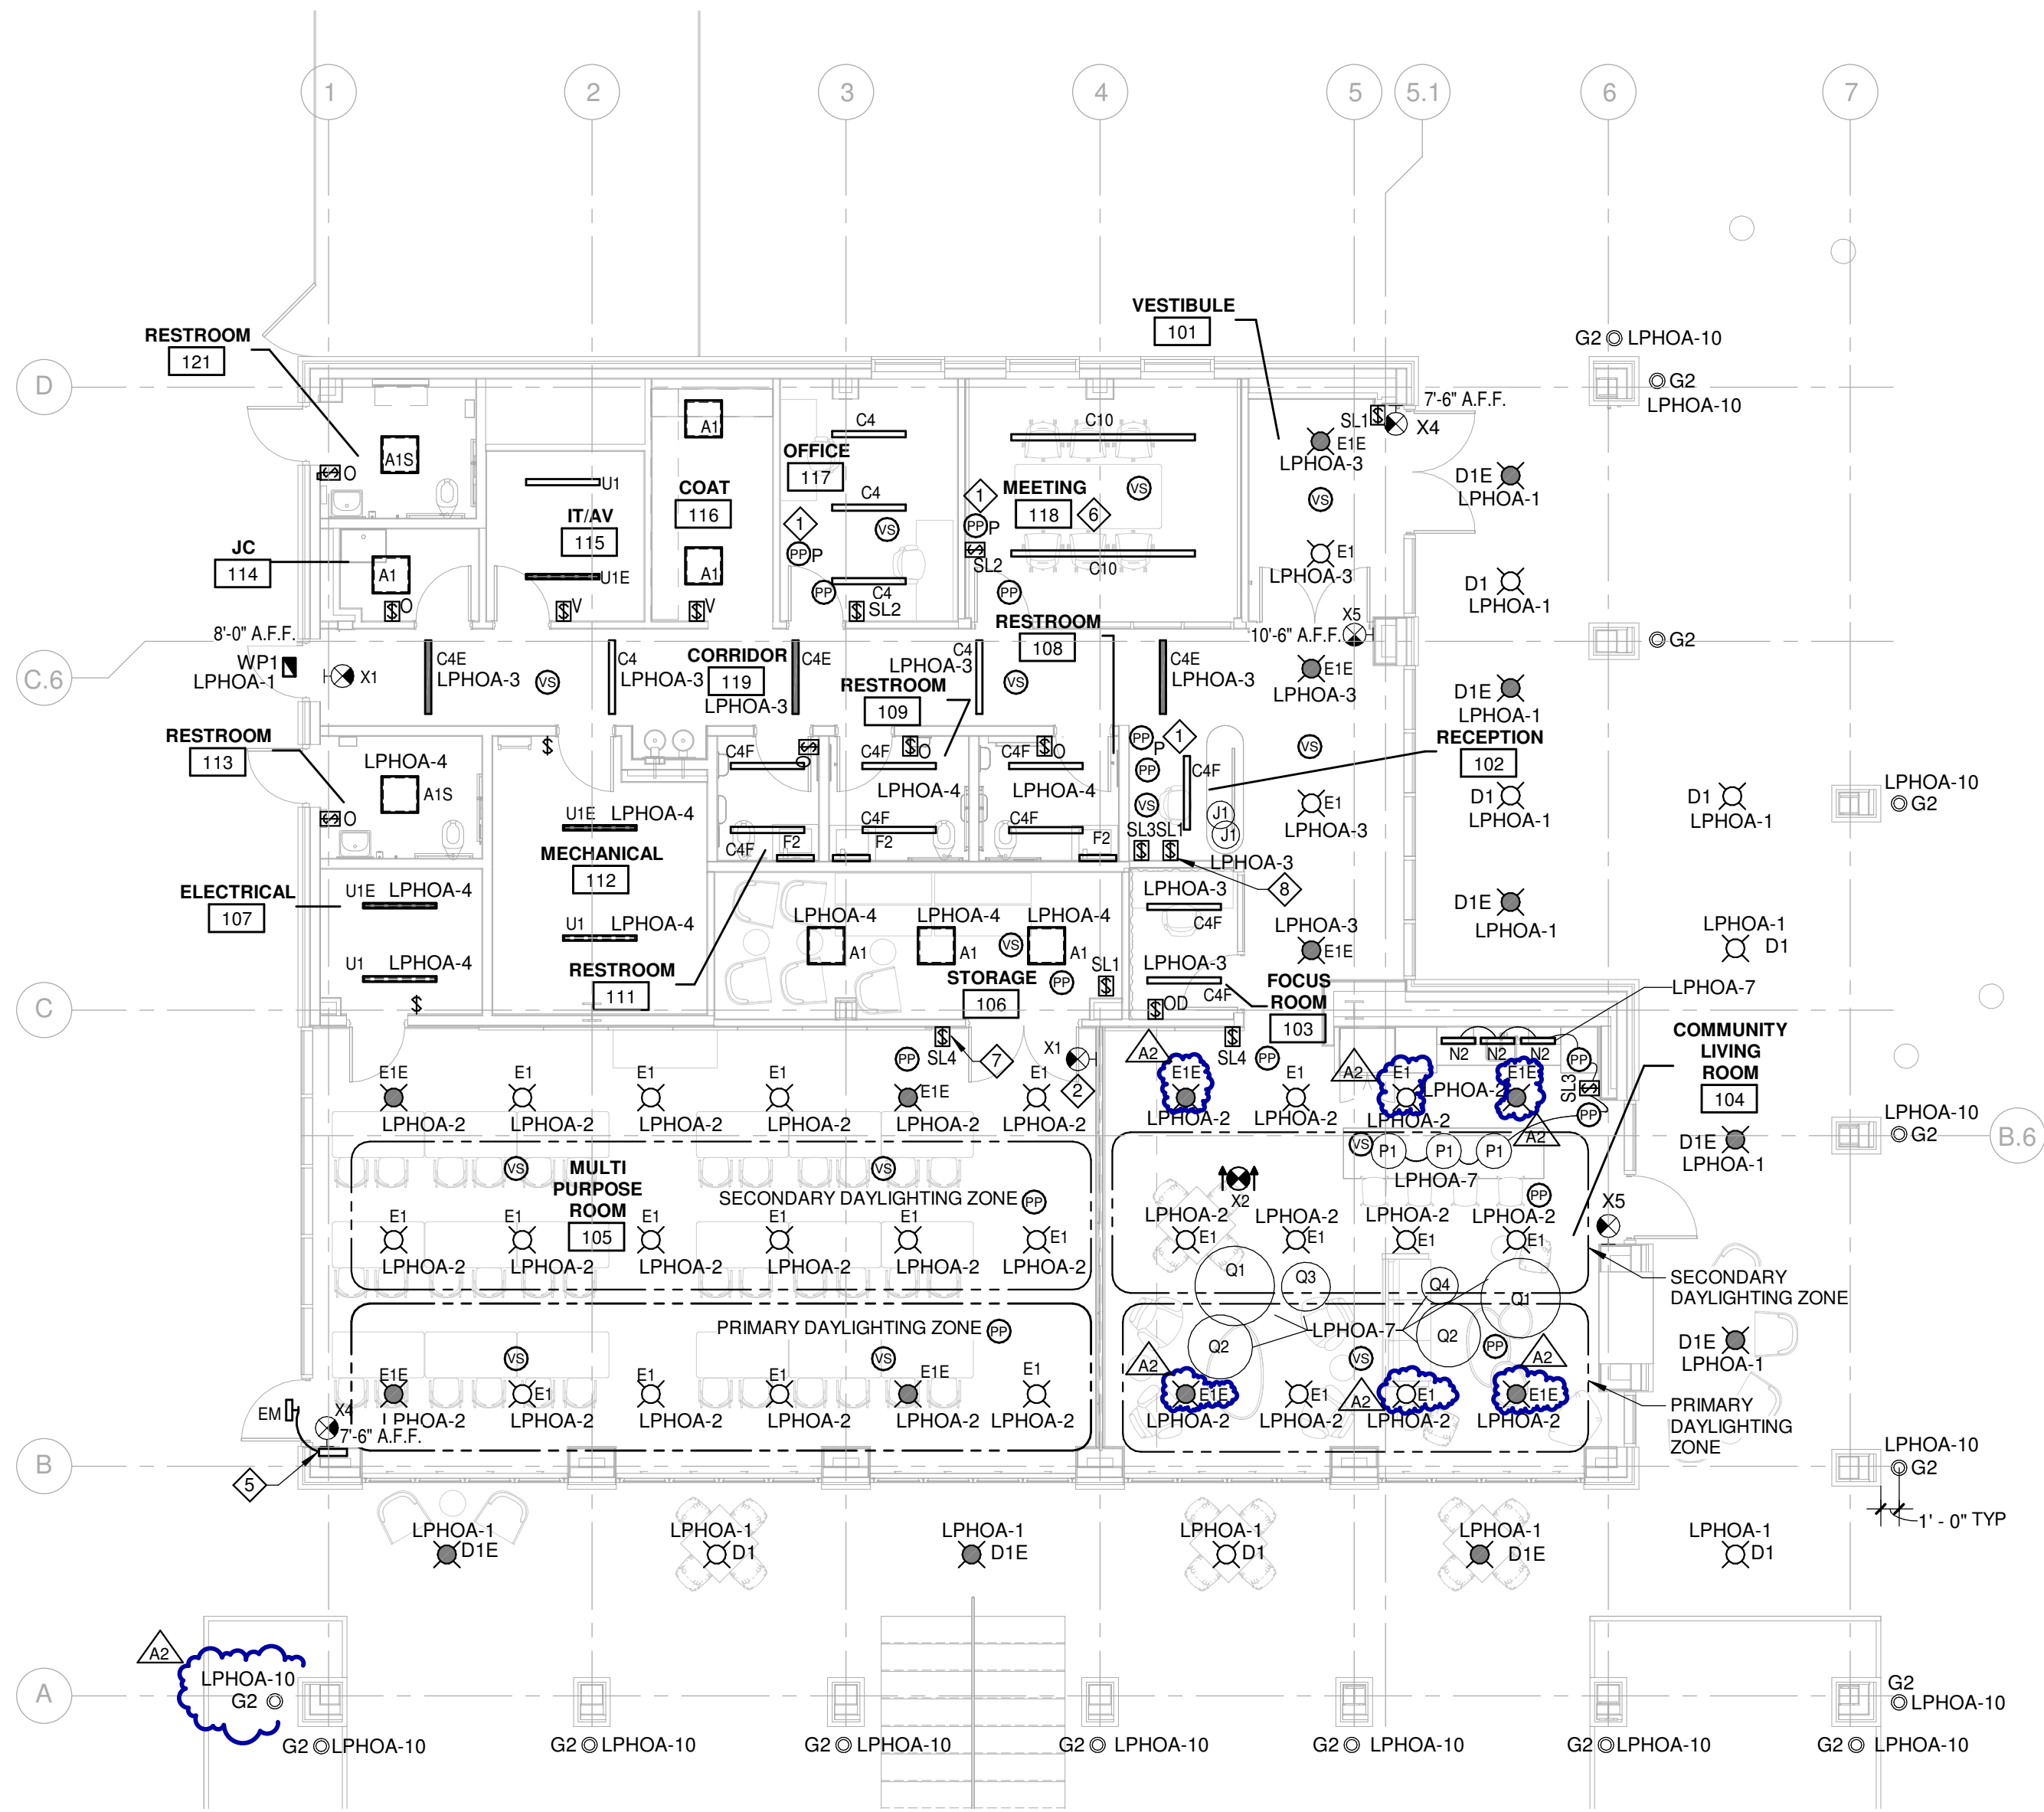

LAKE HOUSE
LIGHTING PLAN - AREA A
SCALE: 1/8" = 1'-0"


GENERAL NOTES

1. REFER TO SHEET E001 FOR GENERAL PROJECT REQUIREMENTS.
2. REFER TO "T SERIES" AND "Y SERIES" DRAWINGS FOR DATA DROP AND SECURITY REQUIREMENTS
3. THE GENERATOR IS A STANDBY GENERATOR AND NOT DESIGNED FOR LIFE SAFETY.
4. EXIT SIGNS SHALL BE SERVED FROM THE LOCAL AREA CIRCUIT, AHEAD OF ANY CONTROLS.
5. EMERGENCY FIXTURES SHALL BE CONTROLLED WITH THE LOCAL AREA LIGHTING AND SERVED FROM THE LOCAL AREA CIRCUIT, AHEAD OF ANY CONTROLS.

KEY NOTES

1. PLUG LOAD CONTROLLER. REFER TO E201 FOR CONTROLLED RECEPTACLES.
2. EXIT SIGN LOCATED ON HEADER ABOVE THE PARTITION WALL.
3. REFER TO THE ELEVATION FOR THE "PEBBLE FIXTURES"
4. ILLUMINATED MIRROR, BRADLEY:7B1-50-0-24
5. REMOTE POWER SUPPLY FOR EM FIXTURE. LOCATE AT 8'0" AFF. PROVIDE 3 GANG RECESSED BOX.
6. PROVIDE BLACK WIRING DEVICES FOR THIS ROOM.
7. PROVIDE BLACK WIRING DEVICE.
8. CORRIDOR LIGHTING CONTROL.

KEY PLAN

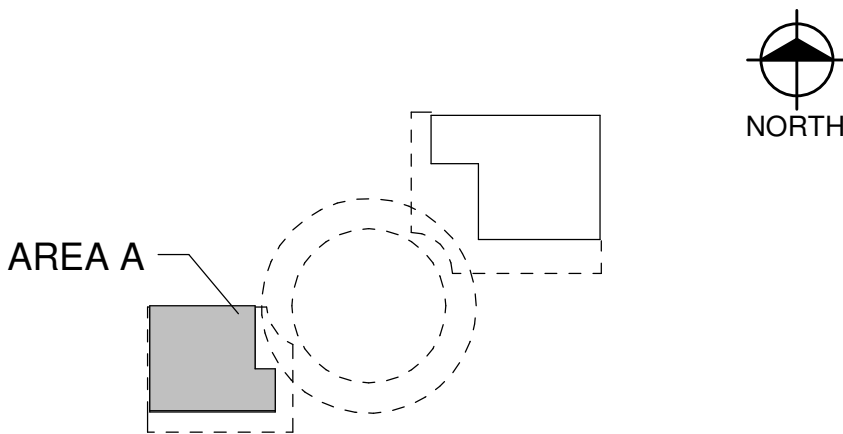

Van Buren Charter Township

Van Buren Township, MI

The Lakeside Park

REVISIONS

NO.	DATE	DESCRIPTION
1	10/27/2026	A2 [ADDENDUM NO. 2]

10/12/2026	BIDS & PERMIT
09/21/2026	CD PEER REVIEW
09/09/2026	CD TEAM REVIEW
08/10/2026	CD 50% PROGRESS
08/22/2026	DD OWNER REVIEW
06/15/2026	DD PEER REVIEW
06/08/2026	DD 90% PROGRESS
05/18/2026	DD 50% PROGRESS
02/23/2026	SD OWNER REVIEW
02/13/2026	SD PEER REVIEW
02/09/2026	SD PROGRESS REVIEW

Drawn By	JMILOCH
Designer	JMILOCH
Reviewer	STKAM
Manager	CKRETOVIC

Hard copy is intended to be 24"x36" when plotted. Scale(s) indicated and graphic quality may not be accurate for any other size.

PROJECT NO.
2500281

SHEET NO.

E101



PLOT INFO: 10/27/2026 11:13:18 AM Autodesk Docs/2500281 - Van Buren Twp Lake House/2026_E_2500281.rvt

3 FEATURE WALL LIGHTING CORRIDOR #168 - WEST

SCALE: 1/8" = 1'-0"

2 FEATURE WALL LIGHTING CORRIDOR #168 - EAST

SCALE: 1/8" = 1'-0"

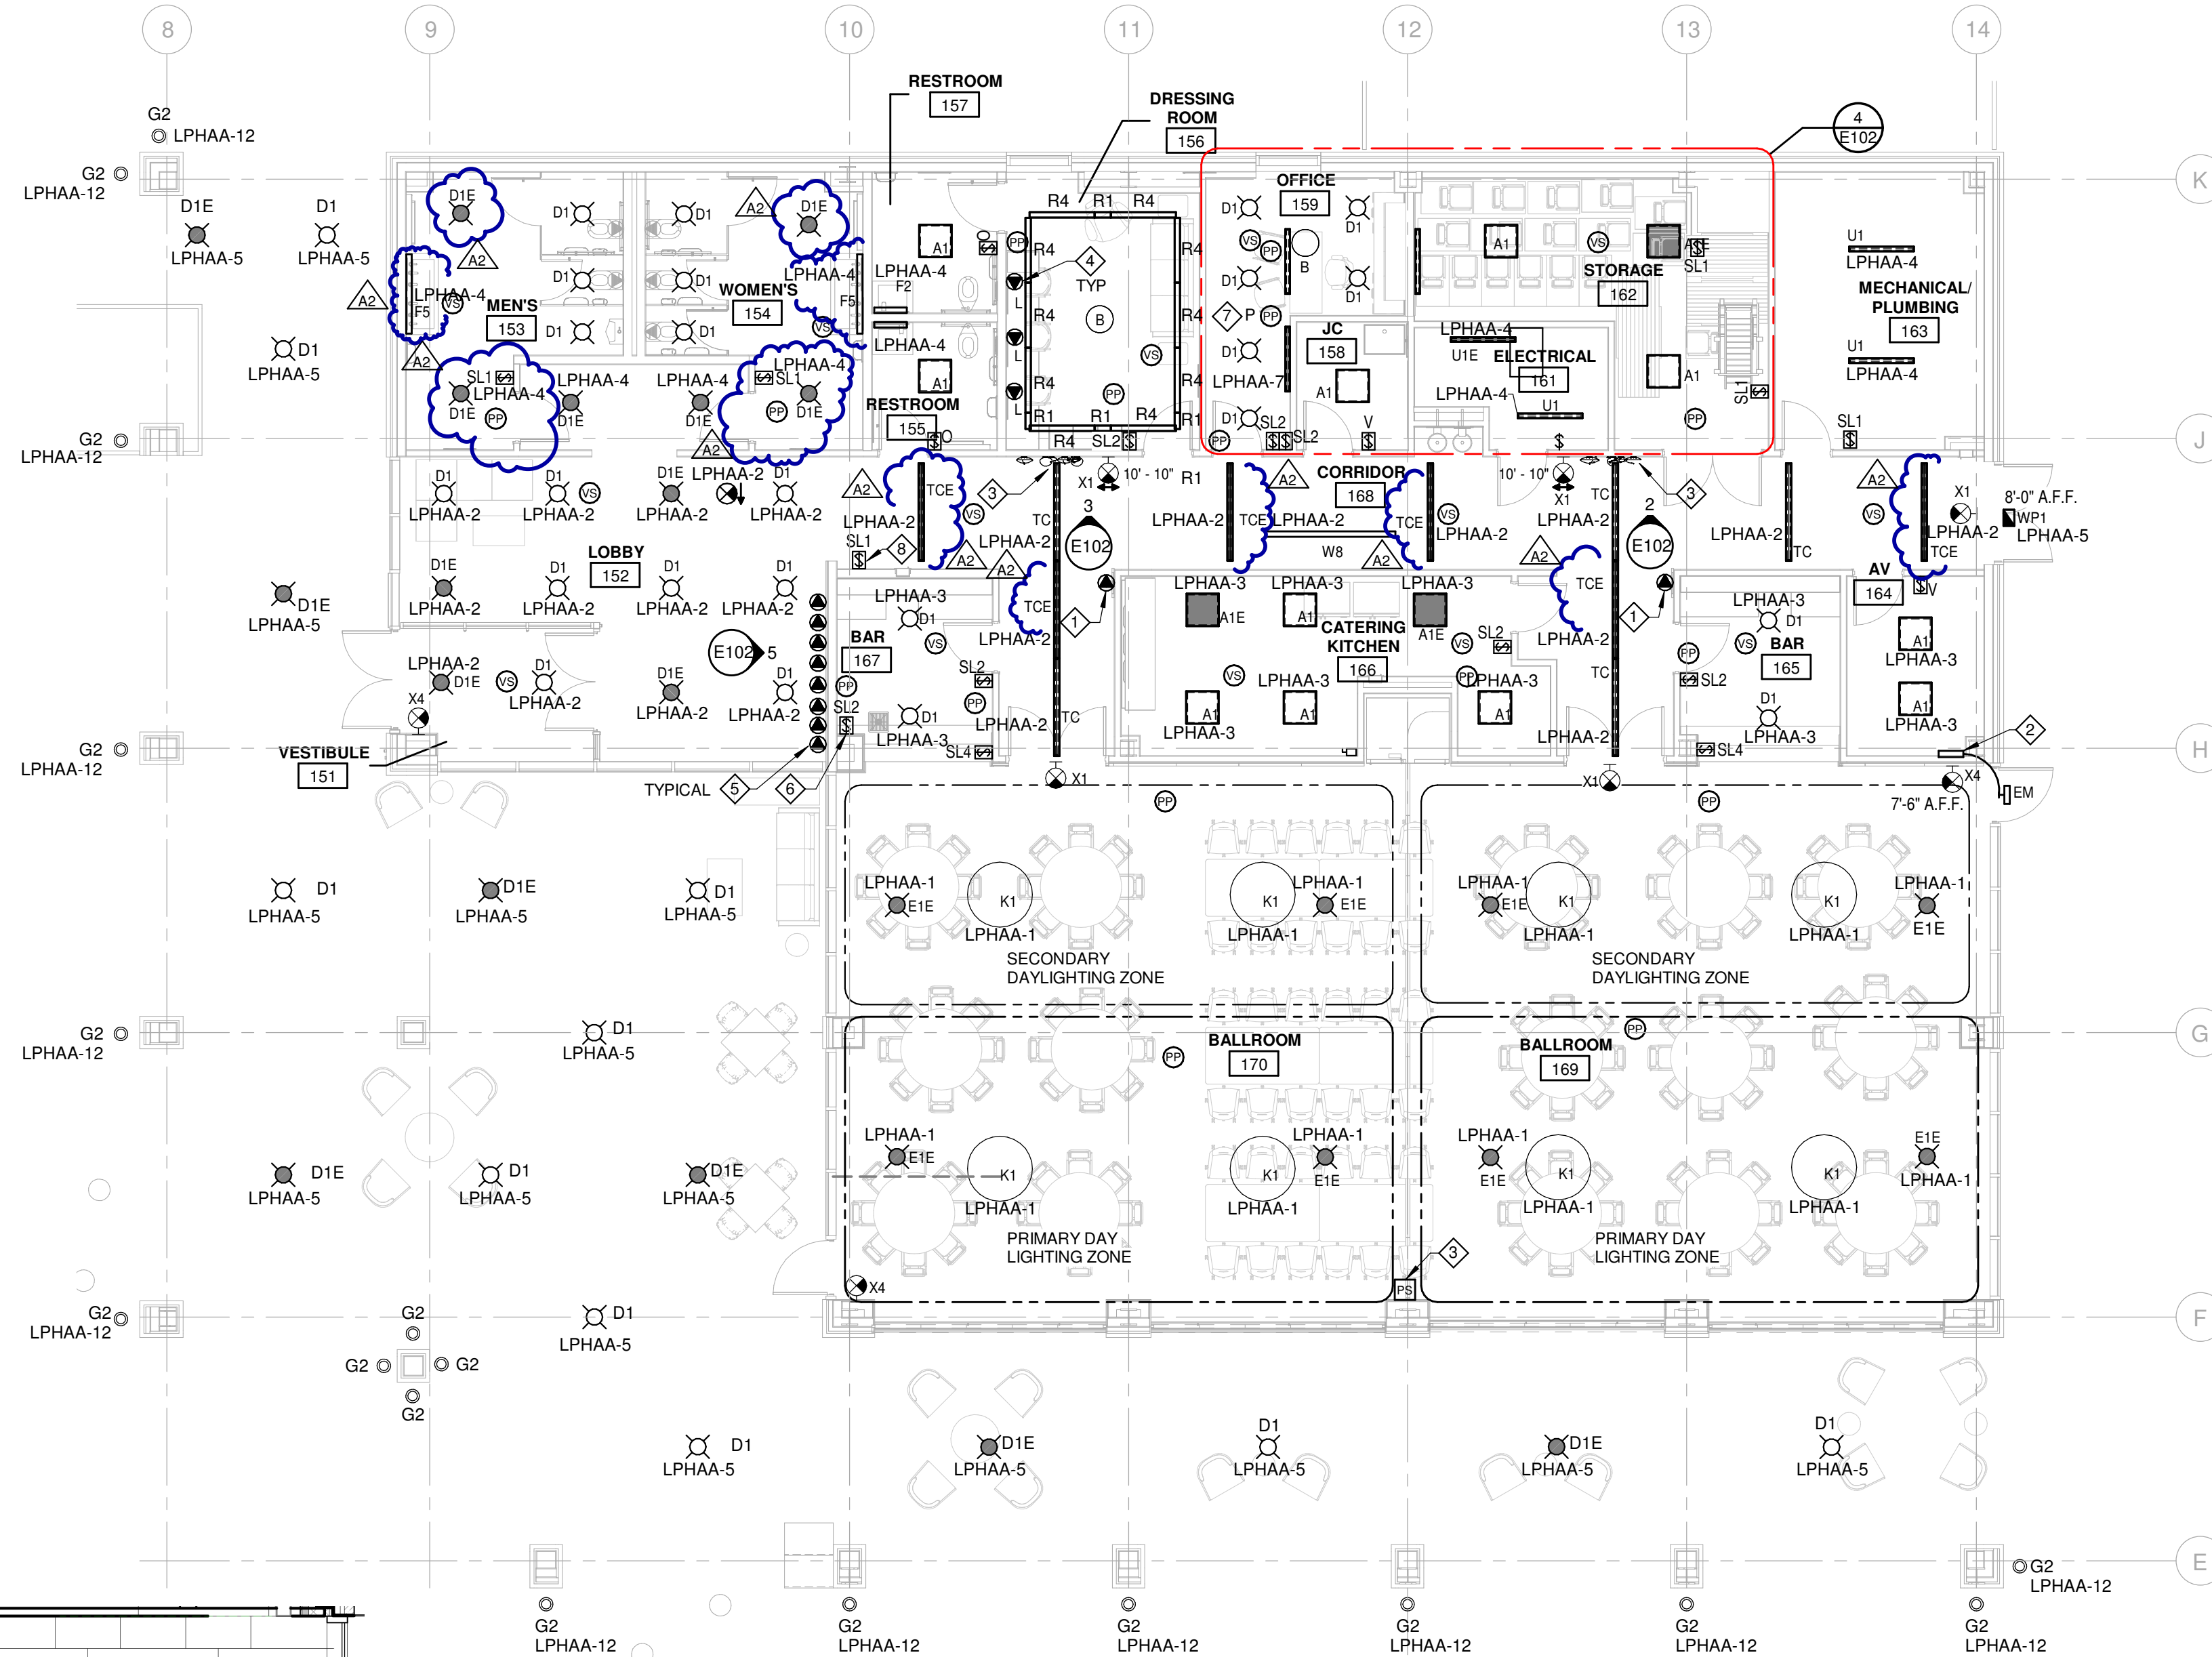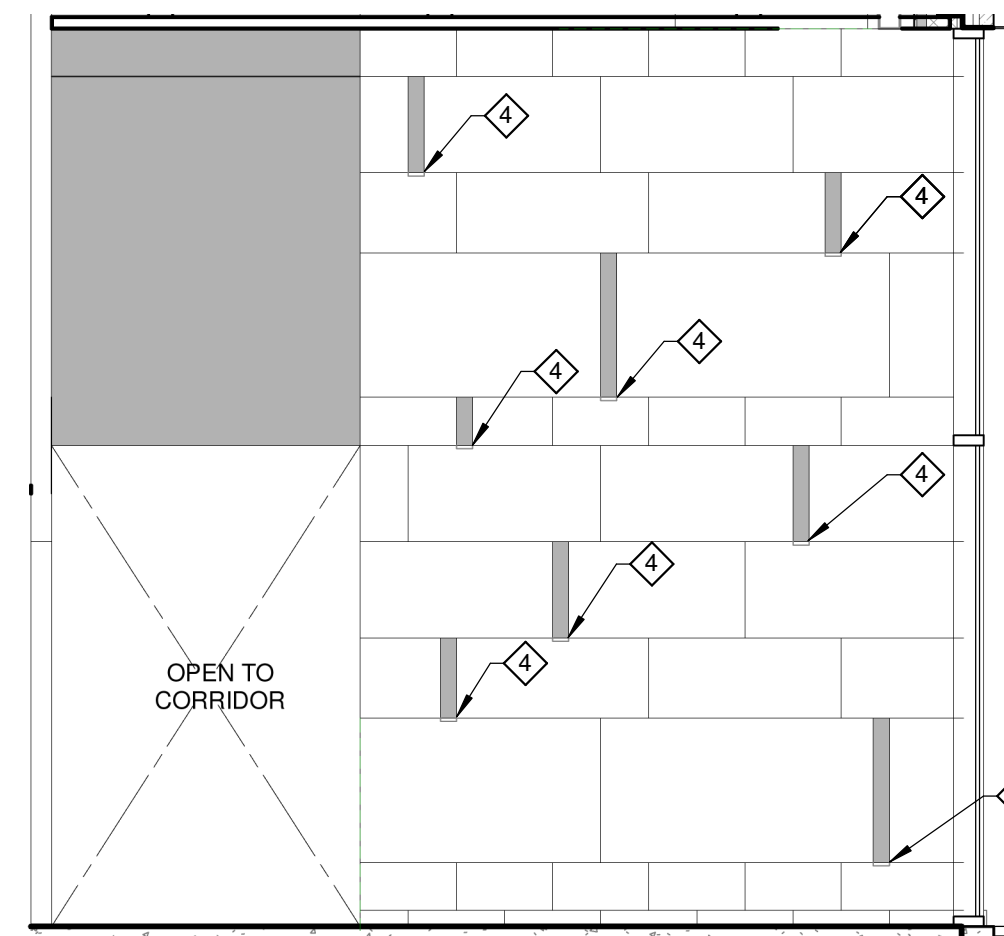


5 LOBBY 152 EAST LIGHTING

SCALE: 1/8" = 1'-0"



LAKE HALL LIGHTING PLAN - AREA B

SCALE: 1/8" = 1'-0"

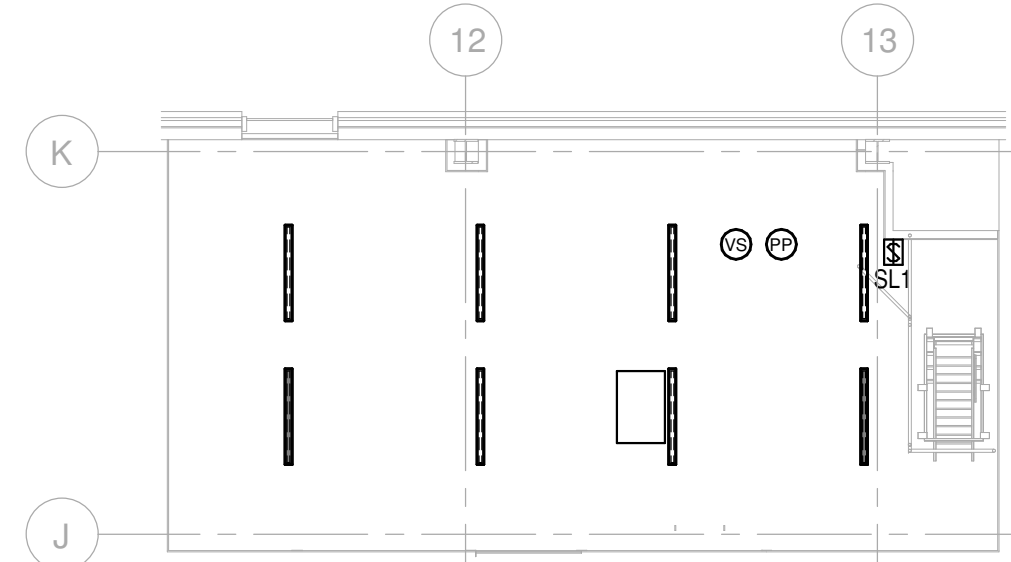

4 LAKE HALL MEZZANINE FLOOR LIGHTING PLAN - AREA B

SCALE: 1/8" = 1'-0"


GENERAL NOTES

1. REFER TO SHEET E001 FOR GENERAL PROJECT REQUIREMENTS.
2. REFER TO "T SERIES" AND "Y SERIES" DRAWINGS FOR DATA DROP AND SECURITY REQUIREMENTS
3. THE GENERATOR IS A STANDBY GENERATOR AND NOT DESIGNED FOR LIFE SAFETY.
4. EXIT SIGNS SHALL BE SERVED FROM THE LOCAL AREA CIRCUIT, AHEAD OF ANY CONTROLS.
5. EMERGENCY FIXTURES SHALL BE CONTROLLED WITH THE LOCAL AREA LIGHTING AND SERVED FROM THE LOCAL AREA CIRCUIT, AHEAD OF ANY CONTROLS.

KEY NOTES

1. PROVIDE A JUNCTION BOX ABOVE THE CEILING FOR FUTURE ILLUMINATED SIGNAGE. CIRCUIT WITH THE ADJACENT LIGHTING AND CONTROLS.
2. REMOTE POWER SUPPLY FOR EM FIXTURE. LOCATE AT 8'0" AFF. PROVIDE 3 GANG RECESSED BOX.
3. PARTITION SENSOR TO WORK IN CONJUNCTION WITH THE LIGHTING CONTROL SYSTEM.
4. TYPE "V", 4" SEGMENT INTEGRATED INTO THE WALL SYSTEM INCLUDING ALL CONNECTORS, DRIVERS, ETC. FOR A COMPLETE SYSTEM.
5. TYPE "V" FIXTURE. REFER TO DETAIL 5 ON THIS SHEET. THESE FIXTURES SHALL HAVE THEIR OWN POWER PACK IN BAR #167, BUT SERVED FROM LPHAA-2 AND CONTROLLED WITH THE LOBBY #152 LIGHTING.
6. DIMMER SWITCH TO ALLOW FOR ADJUSTMENTS TO THE TYPE "V" FIXTURES.
7. PLUG LOAD CONTROLLER. REFER TO E201 FOR CONTROLLED RECEPTACLES.

KEY PLAN

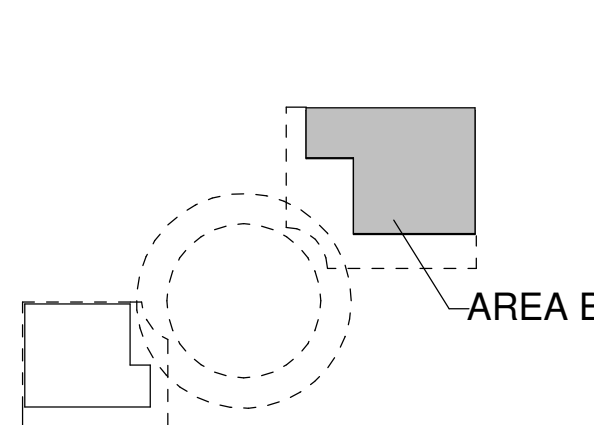

Van Buren Charter Township

Van Buren Township, MI

The Lakeside Park

REVISIONS

DATE	BY	DESCRIPTION
10/27/2026	A2	ADDENDUM NO. 2

10/12/2026	BIDS & PERMIT
09/21/2026	CD PEER REVIEW
09/09/2026	CD TEAM REVIEW
08/10/2026	CD 50% PROGRESS
06/22/2026	DD OWNER REVIEW
06/15/2026	DD PEER REVIEW
06/09/2026	DD 90% PROGRESS
05/18/2026	DD 50% PROGRESS
02/23/2026	SD OWNER REVIEW
02/13/2026	SD PEER REVIEW
02/09/2026	SD PROGRESS REVIEW

Drawn By	JMILOCH
Designer	JMILOCH
Reviewer	STKAM
Manager	CKRETOVIC

Hard copy is intended to be 24"x36" when plotted. Scale(s) indicated and graphic quality may not be accurate for any other size.


PROJECT NO.

2500281

SHEET NO.


E102

©Copyright 2026
All Rights Reserved

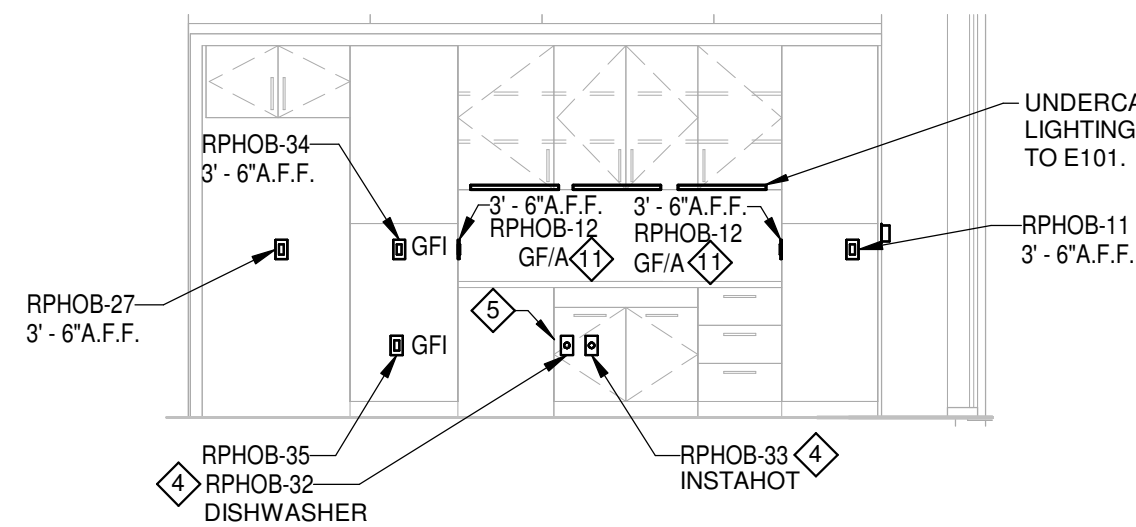


2 COMMUNITY LIVING ROOM KITCHENETTE
SCALE: 1/4" = 1'-0"

SCALE: 1/4" = 1'-0"

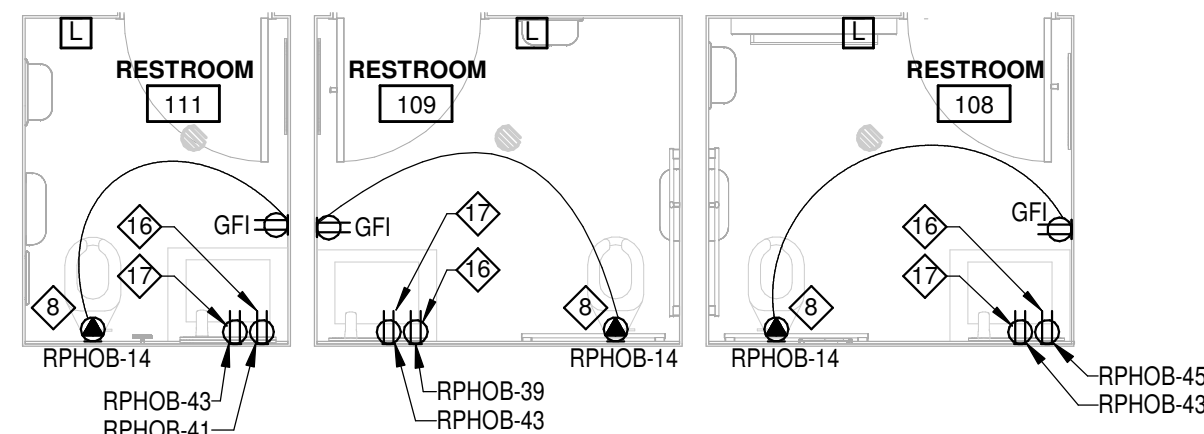

LAKE HOUSE ENLARGED TOILET ROOM PLANS

SCALE: 1/4" = 1'-0"

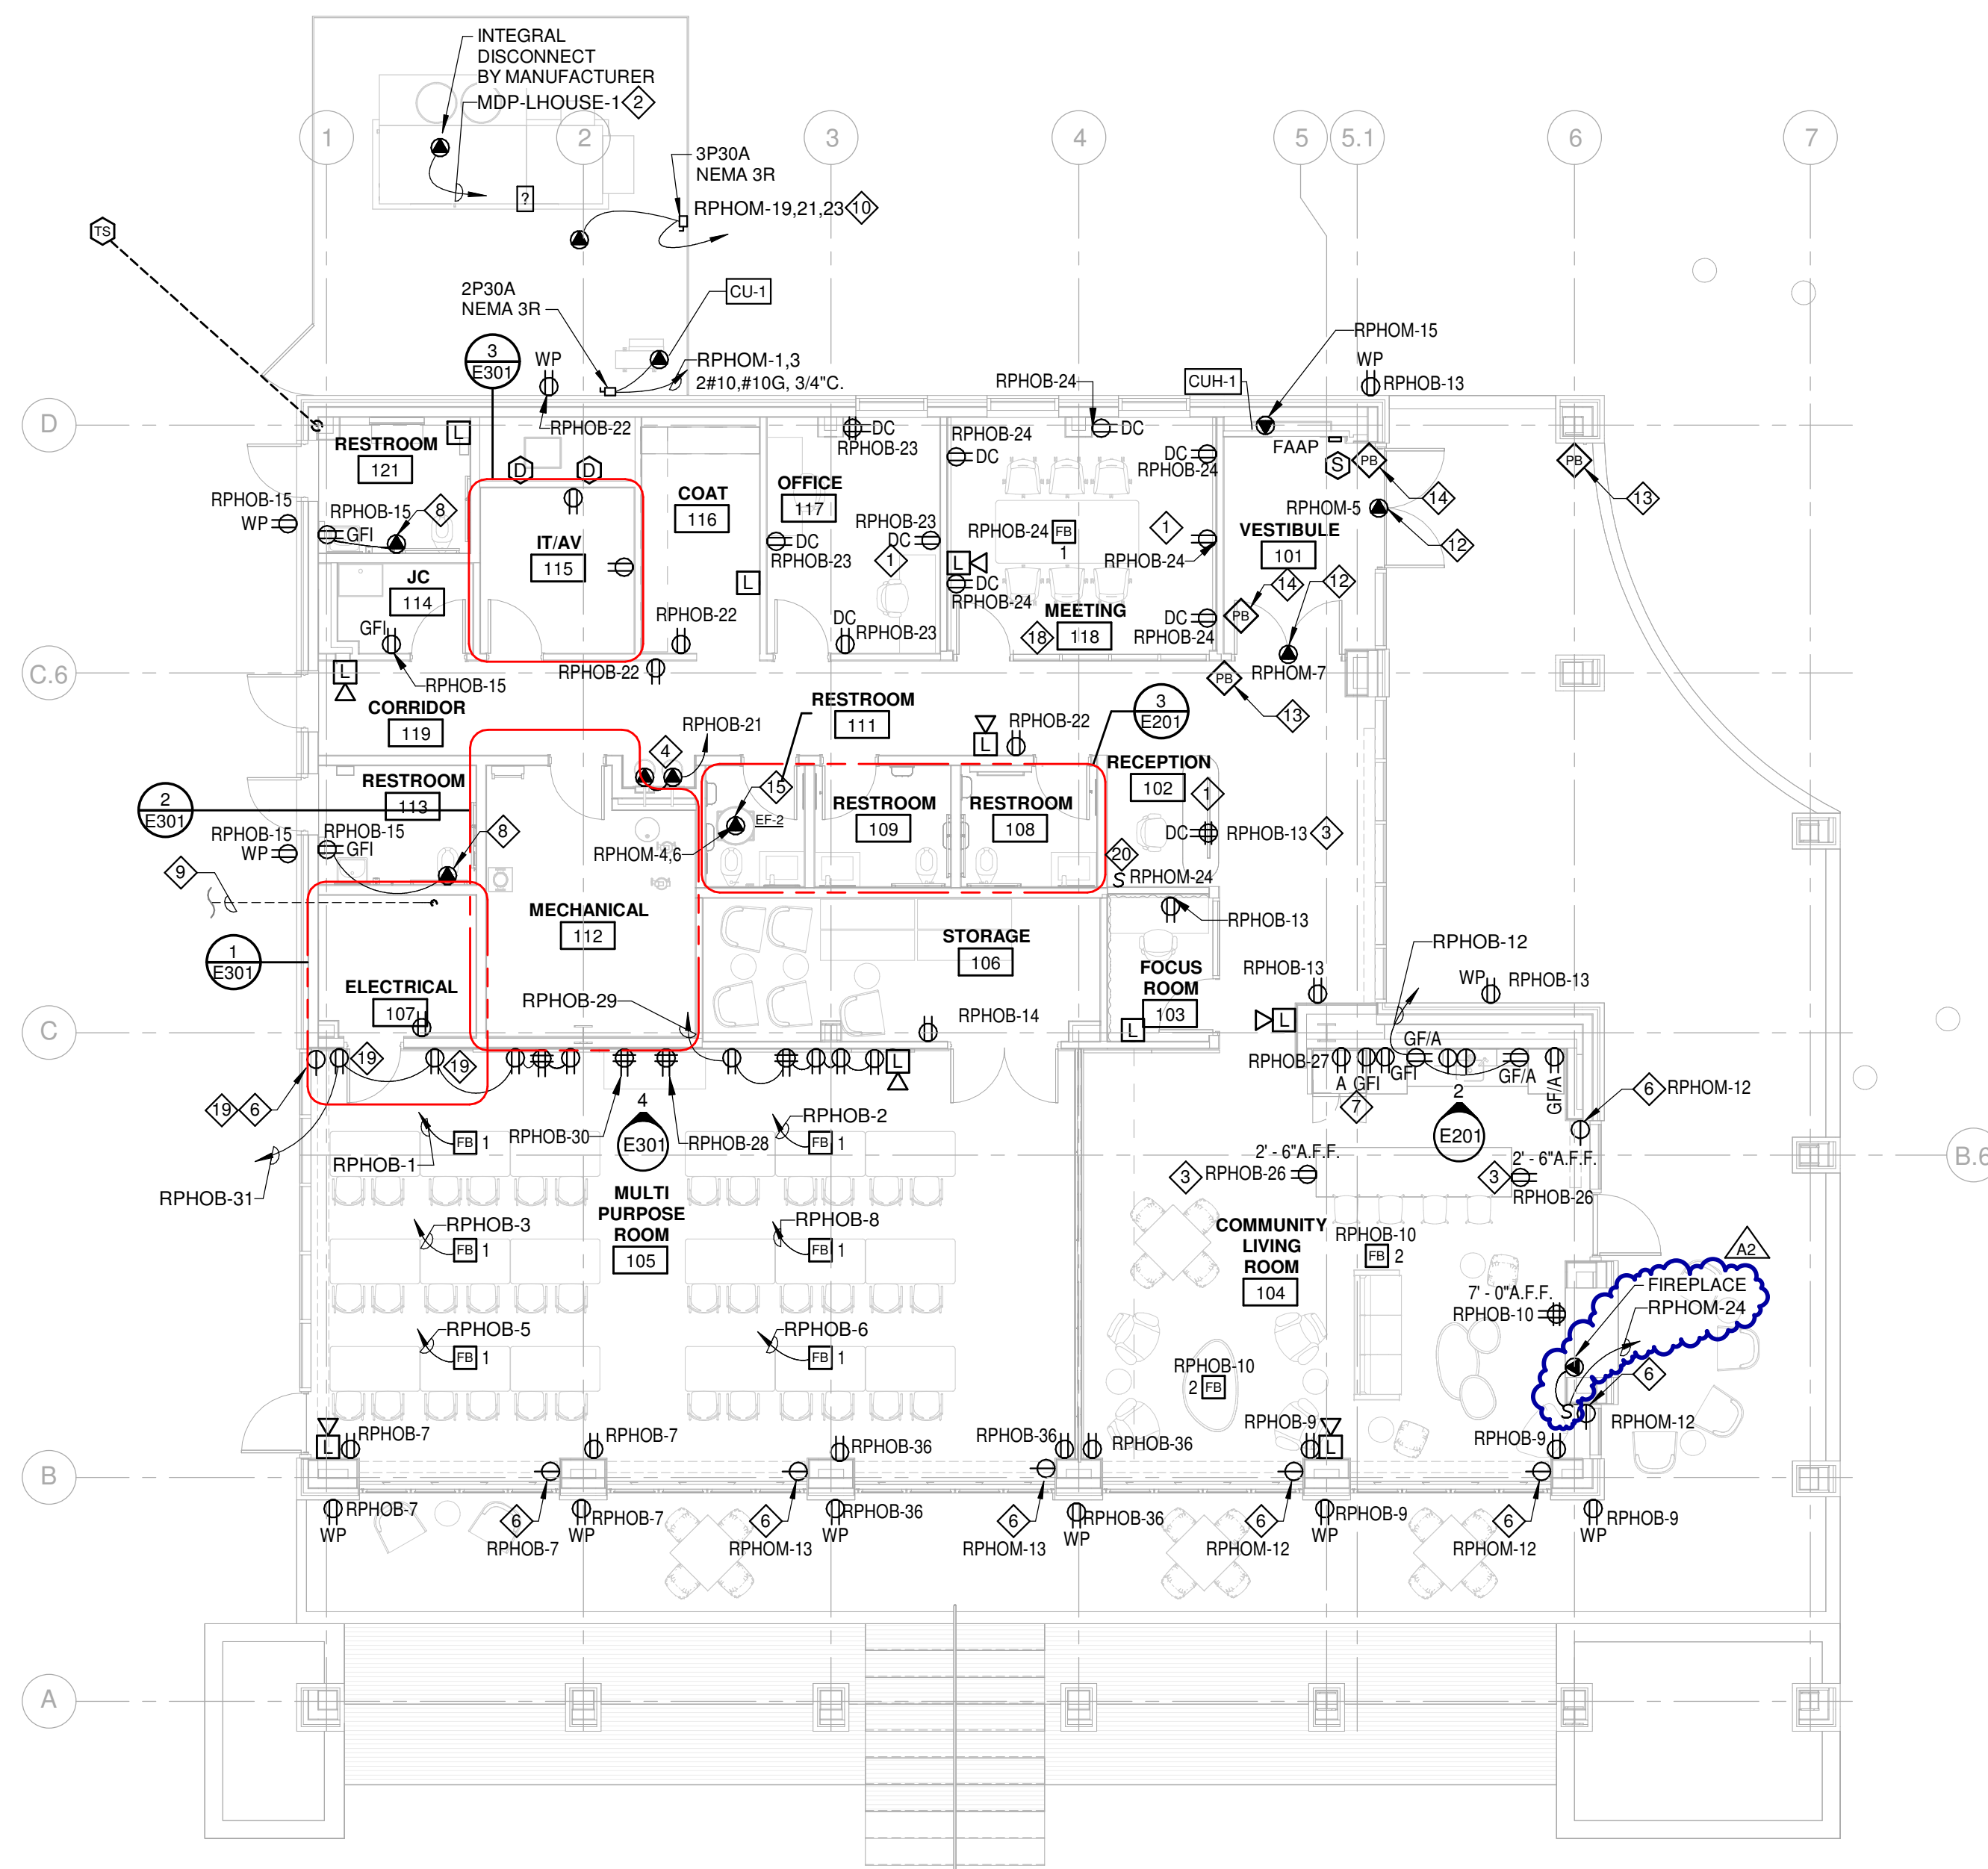

LAKE HOUSE
POWER AND SYSTEMS PLAN - AREA A

SCALE: 1/8" = 1'-0"



NORTH

GENERAL NOTES

1. REFER TO THE GENERAL NOTES ON DRAWING E001 FOR FURTHER REQUIREMENTS.
2. REFER TO E401 FOR FEEDER AND DISCONNECT SIZES.
3. REFER TO THE LIGHTING DRAWINGS TO COORDINATE PLUG LOAD CONTROLS.
4. ACTUAL FURNITURE LAYOUT MAY VARY. COORDINATE DEVICE LAYOUT WITH OWNER AND ACTUAL FURNITURE LAYOUT PRIOR TO ROUGH-IN.
5. THE FIRE ALARM SYSTEM IS SHOWN FOR DESIGN INTENT. REFER TO THE APPROVED FIRE ALARM SHOP DRAWINGS FOR COMPLETE SYSTEM DESIGN REQUIREMENTS.
6. REFER TO THE ARCHITECTURAL DETAILS FOR WALLS WITH ACOUSTIC TREATMENTS THAT REQUIRE COB EXTENSIONS TO ACCOMMODATE THE WALL THICKNESS.

KEY NOTES

- 1 RECEPTACLES SHALL BE SPLIT WIRED SO THAT ONE HALF OF THE DEVICE SHALL BE CONTROLLED BY THE ROOM OCCUPANCY SENSOR TO SHUT OFF THE OCCUPANCY, 20 MIN AFTER LAST OF OCCUPANCY. REFERENCE TO E101 FOR THE PLUG LOAD CONTROLLER.
- 2 REFER TO THE ONE LINE DIAGRAM ON E401 FOR FEEDER SIZE.
- 3 ROUTE MC CABLE THROUGH MILLWORK TO SERVE THE RECEPTACE.
- 4 SERVE FROM GFI CIRCUIT BREAKER IN THE PANELBOARD.
- 5 PROVIDE GROMMET HOLE FOR PASSAGE OF THE DISHWASHER POWER CORD.
- 6 SIMPLEX RECEPTACE AT 15" AFF FOR MOTORIZED SHADES.
- 7 REFER TO THE ELEVATION FOR ADDITIONAL CIRCUIT NUMBERS.
- 8 POWER SUPPLY FOR AUTOMATIC PLUMBING SYSTEMS. LOCATE ABOVE THE CEILING. COORDINATE 120V WIRING WITH THE PLUMBING CONTRACTOR. LOW VOLTAGE WIRING SHALL BE PROVIDED BY THE PLUMBING CONTRACTOR.
- 9 REFER TO THE ELECTRICAL SITE PLAN FOR POWER TO THE SPLASH PAD CONTROL PANEL.
- 10 3/10, #10G, 3/4"C.
- 11 LOCATE THE RECEPTACES IN THE MILLWORK THAT IS PERPENDICULAR TO THE BACKSLASH.
- 12 MOTORIZED DOOR OPERATOR. COORDINATE WITH ARCHITECTURAL TRADES.
- 13 DOOR OPERATOR PUSHBUTTON. 42" AFF
- 14 ROUGH-IN FOR FUTURE DOOR OPERATOR PUSHBUTTON. 42" AFF
- 15 EF-2 ON THE ROOF. LOCAL DISCONNECT BY EQUIPMENT MANUFACTURER. SEE MECH 11F FOR THE SPEED CONTROLLER LOCATION.
- 16 RECEPTACE SERVING SINK HAND DRYER. SERVE FROM A DEDICATED GFI CIRCUIT BREAKER. MOUNT AT 26" AFF TO THE TOP OF THE OUTLET.
- 17 RECEPTACE SERVING SINK ACCESSORIES. SERVE FROM A GFI CIRCUIT BREAKER. MOUNT AT 26" AFF TO THE TOP OF THE OUTLET.
- 18 PROVIDE BLACK WIRING DEVICES FOR THIS ROOM.
- 19 PROVIDE BLACK WIRING DEVICES FOR THIS ROOM.
- 20 ROUTE MC CABLE THROUGH MILLWORK TO SERVE THE RECEPTACE.

References

Van Buren Township, MI

The Lakeside Park

REVISIONS

10/27/2026	A2	ADDENDUM NO. 2
------------	----	----------------

10/12/2026	BIDS & PERMIT
09/21/2026	CD PEER REVIEW
09/09/2026	CD TEAM REVIEW
08/10/2026	CD 50% PROGRESS
06/22/2026	DD OWNER REVIEW
06/15/2026	DD PEER REVIEW
06/08/2026	DD 90 % PROGRESS
05/18/2026	DD 50 % PROGRESS
02/23/2026	SD OWNER REVIEW
02/13/2026	SD PEER REVIEW
02/09/2026	SD PROGRESS REVIEW

Drawn By	JMILOCH
Designer	JMILOCH
Reviewer	STKAM
Manager	CKRETOVIC

Hard copy is intended to be 24"x36" when plotted. Scale(s) indicated and graphic quality may not be accurate for any other size.

PROJECT NO.
2500281


SHEET NO.

E201

©Copyright 2026
All Rights Reserved

PLOT INFO: 10/27/2026 11:13:29 AM Autodesk Docs://2500281 - Van Buren Twp Lake House/2026_E_2500281.rvt

KEY PLAN

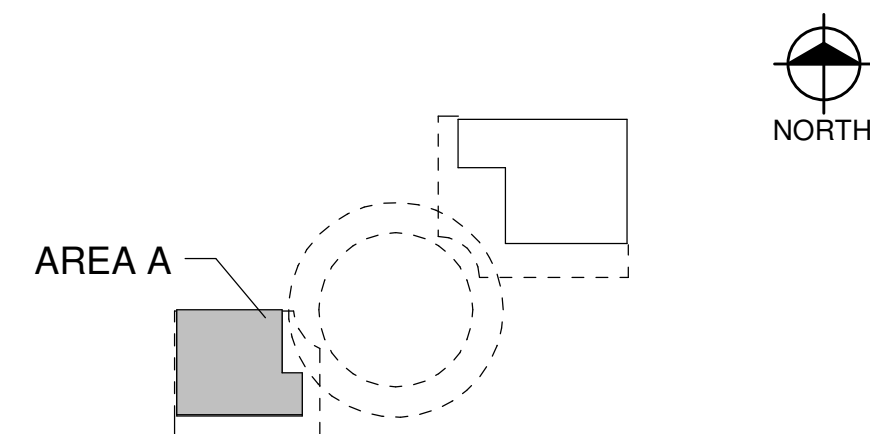

PANEL ID		PANEL DESCRIPTION				
MDP-LHOUSE		NEW 3 PHASE DISTRIBUTION PANEL				
Location: ELECTRICAL 107		Voltage: 208/120 Wye		A.I.C. Rating: 35K		
Supply From: MSB		Phase: 3		Mains Type: MCB		
Mounting: SURFACE		Wires: 4		Mains Rating: 400 A		
Enclosure: NEMA 1				Bussing: COPPER		
CKT	Rev. No.	Circuit Description	# of Poles	Trip Rating	Load	Remarks
1		RTU-1	3	100 A	23913 VA	
2		SPARE	3	100 A	0 VA	
3		SPARE	3	60 A	0 VA	
4		SPARE	3	30 A	0 VA	
5		SPD	3	30 A	0 VA	
6		LPHOA	3	60 A	7260 VA	
7		RPHOB	3	225 A	37520 VA	
8		RPHOM	3	100 A	20340 VA	
9		SPACE	3	--	--	
10		SPACE	3	--	--	
11		SPACE	3	--	--	
12						
13						
14						
15						
16						
17						
18						
19						
20						
			PHASE A	PHASE B	PHASE C	TOTAL AMPS
			31 kVA	29 kVA	29 kVA	247 A
Load Classification		Connected Load	Demand Factor	NEC Calc. Load	Panel Totals	
Equip.		25030 VA	100.00%	25030 VA		
Motor		29753 VA	125.00%	37191 VA	Total Connected Load:	89 kVA
RECEPT		27990 VA	67.86%	18995 VA	Total NEC Calc. Load:	89 kVA
Lighting		5114 VA	125.00%	6393 VA	Total Connected Current:	247 A
LTG		1146 VA	125.00%	1432 VA	Total NEC Calc. Current:	247 A
Notes:						

PANEL ID		PANEL DESCRIPTION											
RPHOB		NEW 3 PHASE PANELBOARD											
Location: ELECTRICAL 107		Voltage: 208/120 Wye				A.I.C. Rating: 22K							
Supply From: MDP-LHOUSE		Phase: 3				Mains Type: MLO							
Mounting: SURFACE		Wires: 4				Rating: 225 A							
Enclosure: NEMA 1		No. of Poles: 72				Bussing: COPPER							
CKT	Rev. No.	Circuit Description	Trip	Poles	A	B	C	Poles	Trip	Circuit Description	Rev. No.	CKT	
1		FB MULT PURP RM 105 NW	20 A	1	180 VA / 180 VA			1	20 A	FB MULT PURP RM 105 NE		2	
3		FB MULT PURP RM 105 MW	20 A	1		180 VA / 180 VA		1	20 A	FB MULT PURP RM 105 ME		4	
5		FB MULT PURP RM 105 SW	20 A	1			180 VA / 180 VA	1	20 A	FB MULT PURP RM 105 SE		6	
7		REC MULT PURP 105 WEST & EXT.	20 A	1	720 VA / 1080 VA			1	20 A	RECEPT MULTI PURPOSE ROOM...		8	
9		REC COM LIV 104 & EXT.	20 A	1		720 VA / 720 VA		1	20 A	REC COM LIV 104 TV & FB		10	
11	G	COMM LIV ROOM COUNTER	20 A	1			1200 VA / 540 VA	1	20 A	COMM LIV ROOM COUNTER		12	
13		RECEPT ROOMS 640, 102, 103.	20 A	1	1080 VA / 870 VA			1	20 A	RECEPT STORAGE 106		14	
15		RECEPT	20 A	1		1000 VA / 2000 VA		2	30 A	Equip. IT 115		16	
17		Equip. IT 115	30 A	2			2000 VA / 2000 VA	--			--	18	
19	--	--	--	--	2000 VA / 1720 VA			1	20 A	SECURITY PANEL RECEPT IT 115		20	
21	G	EWG CORRIDOR 119	15 A	1		600 VA / 1080 VA		1	20 A	RECEPT		22	
23		RECEPT OFFICE 117	20 A	1			900 VA / 1260 VA	1	20 A	RECEPT MEETING 118		24	
25		SPARE	20 A	1	0 VA / 720 VA			1	20 A	RECEPT COM LIV ISLAND		26	
27	G	REFRIGERATOR	20 A	1		720 VA / 360 VA		1	20 A	RECEPT MULTI PURPOSE ROOM...		28	
29		REC MULT PUP 105 NE FRONT105	20 A	1			1080 VA / 360 VA	1	20 A	RECEPT MULTI PURPOSE ROOM...		30	
31		REC MULT PUP 105 NW FRONT	20 A	1	1080 VA / 1440 VA			1	20 A	DISHWASHER CLR 104	G	32	
33	G	INSTAHOT CLR 103	20 A	1		750 VA / 1000 VA		1	20 A	MICROWAVE COMM LIV RM TOP		34	
35		MICROWAVE COMM LIV RM BOT	20 A	1			1000 VA / 900 VA	1	20 A	REC MULT PURP 105 EAST & EXT.		36	
37		Equip. AV 107	20 A	1	500 VA / 0 VA							38	
39	G	RESTROOM 109 HAND DRYER	20 A	1		1500 VA / 0 VA						40	
41	G	RESTROOM 111 HAND DRYER	20 A	1			1500 VA / 0 VA	1	20 A	SPARE		42	
43	G	RECEPT REST 108, 109, 111	20 A	1	540 VA / 0 VA			1	20 A	SPARE		44	
45	G	RESTROOM 108 HAND DRYER	20 A	1		1500 VA / 0 VA		1	20 A	SPARE		46	
47		SPARE	20 A	1			0 VA / 0 VA	1	20 A	SPARE		48	
49		SPARE	20 A	1	0 VA / 0 VA			1	20 A	SPARE		50	
51		SPARE	20 A	1		0 VA / 0 VA		1	--	SPACE		52	
53		SPARE	20 A	1			0 VA / 0 VA	1	--	SPACE		54	
55		SPARE	20 A	1	0 VA / 0 VA			1	--	SPACE		56	
57		SPACE	--	1		0 VA / 0 VA		1	--	SPACE		58	
59		SPACE	--	1			0 VA / 0 VA	1	--	SPACE		60	
61		SPACE	--	1	0 VA / 0 VA			1	--	SPACE		62	
63		SPACE	--	1		0 VA / 0 VA		1	--	SPACE		64	
65		SPACE	--	1			0 VA / 0 VA	1	--	SPACE		66	
67		SPACE	--	1	0 VA / 0 VA			1	--	SPACE		68	
69		SPACE	--	1		0 VA / 0 VA		1	--	SPACE		70	
71		SPACE	--	1			0 VA / 0 VA	1	--	SPACE		72	
Total Load:					12110 VA	12310 VA	13100 VA						
Total Amps:					101 A	103 A	109 A						
Load Classification				Connected Load	Demand Factor	Estimated Demand	Panel Totals						
RECEPT				25830 VA	69.36%	17915 VA							
Equip.				11690 VA	100.00%	11690 VA	Total Connected Load: 37520 VA						
							Total Estimated Demand: 29605 VA						
							Total Connected Current: 104 A						
							Total Est. Demand Current: 82 A						
Notes: G = GFI CIRCUIT BREAKER													

PANEL ID		PANEL DESCRIPTION											
LPHOA		NEW 3 PHASE PANELBOARD											
Location: ELECTRICAL 107		Voltage: 208/120 Wye						A.I.C. Rating: 22K					
Supply From: MDP-LHOUSE		Phase: 3						Mains Type: MLO					
Mounting: SURFACE		Wires: 4						Rating: 100 A					
Enclosure: NEMA 1		No. of Poles: 30						Bussing: COPPER					
CKT	Rev. No.	Circuit Description	Trip	Poles	A	B	C	Poles	Trip	Circuit Description	Rev. No.	CKT	
1		EXT SOFFIT LTG--LAKE HOUSE	20 A	1	474 VA / 619 VA			1	20 A	LTG MP 105 / COMM LIVING 104		2	
3		LTG CORR 119 / RECEPT 102	20 A	1		518 VA / 513 VA		1	20 A	LTG SUPPORT RMS 106-113		4	
5		SW SITE LIGHTING	20 A	1			460 VA / 244 VA	1	20 A	CENTRAL PATHWAY LTG		6	
7		Lighting COMMUNITY LIVING ROO...	20 A	1	1131 VA / 501 VA			1	20 A	Lighting MEETING 118		8	
9		MARQUEE SIGN POWER	20 A	1		1000 VA / 840 VA		1	20 A	Lighting		10	
11		SPARE	20 A	1			0 VA / 960 VA	1	20 A	Lighting		12	
13		SPARE	20 A	1	0 VA / 0 VA			1	20 A	SPARE		14	
15		SPARE	20 A	1		0 VA / 0 VA		1	20 A	SPARE		16	
17		SPACE	--	1			0 VA / 0 VA	1	--	SPACE		18	
19		SPACE	--	1	0 VA / 0 VA			1	--	SPACE		20	
21		SPACE	--	1		0 VA / 0 VA		1	--	SPACE		22	
23		SPACE	--	1			0 VA / 0 VA	1	--	SPACE		24	
25		SPACE	--	1	0 VA / 0 VA			1	--	SPACE		26	
27		SPACE	--	1		0 VA / 0 VA		1	--	SPACE		28	
29		SPACE	--	1			0 VA / 0 VA	1	--	SPACE		30	
Total Load:					2724 VA	2871 VA	1664 VA						
Total Amps:					24 A	25 A	14 A						
Load Classification				Connected Load		Demand Factor		Estimated Demand		Panel Totals			
Lighting				5114 VA		125.00%		6393 VA		Total Connected Load: 7260 VA			
Equip.				1000 VA		100.00%		1000 VA		Total Estimated Demand: 8824 VA			
LTG				1146 VA		125.00%		1432 VA		Total Connected Current: 20 A			
										Total Est. Demand Current: 24 A			
Notes:													

PANEL ID		PANEL DESCRIPTION											
RPHOM		NEW 3 PHASE PANELBOARD											
Location: ELECTRICAL 107		Voltage: 208/120 Wye				A.I.C. Rating: 18K							
Supply From: MDP-LHOUSE		Phase: 3				Mains Type: MLO							
Mounting: SURFACE		Wires: 4				Rating: 125 A							
Enclosure: NEMA 1		No. of Poles: 42				Bussing: COPPER							
CKT	Rev. No.	Circuit Description	Trip	Poles	A	B	C	Poles	Trip	Circuit Description	Rev. No.	CKT	
1	--	CU-1	15 A	2	936 VA / 500 VA			1	15 A	CUH-1 VESTIBULE 101	--	2	
3	--	--	--	--		936 VA / 156 VA		2	15 A	EF-2 (ROOF ABOVE RR 111)	--	4	
5	--	EXT. VEST 101 DOOR OPER	20 A	1			540 VA / 156 VA	--	--	--	--	6	
7	--	INT. VEST 101 DOOR OPER	20 A	1	540 VA / 510 VA			2	15 A	HP-1 MECHANICAL 112	--	8	
9	--	HP-2 MECHANICAL 112	15 A	2		510 VA / 510 VA		--	--	--	--	10	
11	--	--	--	--			510 VA / 900 VA	1	20 A	SHADES COMMUNITY LV RM	--	12	
13	--	SHADES MULTI PURPOSE	20 A	1	720 VA / 1200 VA			1	15 A	SPLASH PAD EQUIPMENT 1	--	14	
15	--	CUH-1	20 A	1		136 VA / 540 VA		1	20 A	WH-1 & DHWP-1 MECHANICAL 112	--	16	
17	--	BMS LAKEHOUSE MECH 112	20 A	1			500 VA / 1267 VA	3	20 A	DWPB-1	--	18	
19	--	RTU-1 EXHAUST FAN	30 A	3	1633 VA / 1267 VA			--	--	--	--	20	
21	--	--	--	--		1633 VA / 1267 VA		--	--	--	--	22	
23	--	--	--	--			1633 VA / 840 VA	1	20 A	FIREPLACE COMM AND FIRE PIT	--	24	
25	--	BOILER B-1, BP-1	15 A	1	500 VA / 0 VA			1	20 A	SPACE	--	26	
27	--	BOILER B-2, BP-2	15 A	1		500 VA / 0 VA		1	20 A	SPACE	--	28	
29	--	SPARE	20 A	1			0 VA / 0 VA	1	20 A	SPACE	--	30	
31	--	SPARE	20 A	1	0 VA / 0 VA			1	20 A	SPACE	--	32	
33	--	SPARE	20 A	1		0 VA / 0 VA		1	20 A	SPACE	--	34	
35	--	SPARE	20 A	1			0 VA / 0 VA	1	20 A	SPACE	--	36	
37	--	SPARE	20 A	1	0 VA / 0 VA			1	--	SPACE	--	38	
39	--	SPARE	20 A	1		0 VA / 0 VA		1	--	SPACE	--	40	
41	--	SPARE	20 A	1			0 VA / 0 VA	1	--	SPACE	--	42	
Total Load:					7806 VA	6188 VA	6346 VA						
Total Amps:					65 A	52 A	53 A						
Load Classification			Connected Load	Demand Factor	Estimated Demand		Panel Totals						
Motor			10740 VA	125.00%	13425 VA								
RECEPT			2160 VA	100.00%	2160 VA		Total Connected Load: 20340 VA						
Equip.			7440 VA	100.00%	7440 VA		Total Estimated Demand: 23025 VA						
							Total Connected Current: 56 A						
							Total Est. Demand Current: 64 A						
Notes:													

PLOT INFO: 10/27/2026 11:13:42 AM Autodesk Docs://2500281 - Van Buren Twp Lake House/2026_E_2500281.rvt

PANEL ID		PANEL DESCRIPTION				
MDP-LHALL		NEW 3 PHASE DISTRIBUTION PANEL				
Location: ELECTRICAL 161		Voltage: 208/120 Wye		A.I.C. Rating: 35K		
Supply From: MSB		Phase: 3		Mains Type: MCB		
Mounting: SURFACE		Wires: 4		Mains Rating: 600 A		
Enclosure: NEMA 1		Bussing: COPPER				
CKT	Rev. No.	Circuit Description	# of Poles	Trip Rating	Load	Remarks
1		RTU-2	3	200 A	56535 VA	
2		LPHAA	3	20 A	5366 VA	
3		RPHAB	3	225 A	58730 VA	
4		RPHAM	3	100 A	11857 VA	
5		GPS-1	3	30 A	3963 VA	
6		SPD	3	20 A	0 VA	
7		SPARE	3	100 A	0 VA	
8		SPARE	3	60 A	0 VA	
9		SPARE	3	30 A	0 VA	
10		100A SPACE	3	--	--	
11		100A SPACE	3	--	--	
12		100A SPACE	3	--	--	
13						
14						
15						
16						
17						
18						
19						
20						
			PHASE A	PHASE B	PHASE C	TOTAL AMPS
			44 kVA	48 kVA	44 kVA	379 A
Load Classification		Connected Load	Demand Factor	NEC Calc. Load	Panel Totals	
Equip.		20400 VA	100.00%	20400 VA		
Heating		120 VA	125.00%	150 VA	Total Connected Load: 136 kVA	
Motor		58685 VA	125.00%	73356 VA	Total NEC Calc. Load: 136 kVA	
Other		180 VA	100.00%	180 VA	Total Connected Current: 379 A	
RECEPT		27100 VA	68.45%	18550 VA	Total NEC Calc. Current: 378 A	
Lighting		4054 VA	125.00%	5067 VA		
LTG		1313 VA	125.00%	1641 VA		
REC		2000 VA	100.00%	2000 VA		
Notes:						

PANEL ID		PANEL DESCRIPTION				
MSB		NEW 3 PHASE SWITCHBOARD				
Location:		ELECTRICAL 161	Voltage: 208/120 Wye		A.I.C. Rating: 65K	
Supply From:			Phase: 3		Mains Type: MLO	
Mounting:			Wires: 4		Mains Rating: 1000 A	
Enclosure: Type 1		Bussing:				
CKT	Rev. No.	Circuit Description	# of Poles	Trip Rating	Load	Remarks
1		MDP-LHALL (ATS-1)	3	600 A	136451 VA	
2		MDP-LHOUSE	3	400 A	89032 VA	
3						
4						
			PHASE A	PHASE B	PHASE C	TOTAL AMPS
			75 kVA	77 kVA	74 kVA	626 A
Load Classification		Connected Load	Demand Factor	NEC Calc. Load	Panel Totals	
Equip.		69343 VA	100.00%	69343 VA		
Heating		120 VA	125.00%	150 VA	Total Connected Load: 225 kVA	
Motor		64525 VA	125.00%	80656 VA	Total NEC Calc. Load: 214 kVA	
Other		180 VA	100.00%	180 VA	Total Connected Current: 626 A	
RECEPT		55080 VA	50.08%	32545 VA	Total NEC Calc. Current: 594 A	
Lighting		9168 VA	125.00%	11480 VA		
LTG		2458 VA	125.00%	3073 VA		
REC		2000 VA	100.00%	2000 VA		
Notes:						

PANEL ID		PANEL DESCRIPTION											
RPHAB		NEW 3 PHASE PANELBOARD											
Location: ELECTRICAL 161		Voltage: 208/120 Wye				A.I.C. Rating: 22K							
Supply From: MDP-LHALL		Phase: 3				Mains Type: MCB							
Mounting: SURFACE		Wires: 4				Rating: 400 A							
Enclosure: NEMA 1		No. of Poles: 84				Bussing: COPPER							
CKT	Rev. No.	Circuit Description	Trip	Poles	A	B	C	Poles	Trip	Circuit Description	Rev. No.	CKT	
1		RESTROOM / LOBBY RECEPT	20 A	1	870 VA / 460 VA			1	20 A	RESTROOM 155/157 RECEPT		2	
3		RECEPT DRESSING ROOM 156	20 A	1		360 VA / 360 VA		1	20 A	RECEPT DRESSING ROOM 156		4	
5		RECEPT DRESSING ROOM 156	20 A	1			360 VA / 900 VA	1	20 A	RECEPT JC 156		6	
7		EWIC CORRIDOR 168 - GFI	20 A	1	180 VA / 1440 VA			1	20 A	CORR / JC / STOR RECEPT		8	
9		MECH/PLBG 163 & EXT RECEPT	20 A	1		720 VA / 900 VA		1	20 A	RECEPT BALLROOM 170		10	
11		RECEPT BALLROOM 169	20 A	1			1080 VA / 1000 VA	1	20 A	REC AV 164 EQUIP RACK		12	
13		REC AV 164 EQUIP RACK	20 A	1	1000 VA / 0 VA			1	20 A	REC AV 164 ACCESS CONTROL...		14	
15		TELECOM RACK L6-30 RECEPT	30 A	2		2000 VA / 2000 VA		2	30 A	TELECOM RACK L6-30 RECEPT		16	
17	--	--	--	--			2000 VA / 2000 VA	--	--	--	--	18	
19	G	BEER DISPENSER BAR 167	15 A	1	504 VA / 180 VA			1	20 A	RECEPT BAR 167		20	
21		RECEPT BALLROOM 170	20 A	1		720 VA / 1200 VA		1	20 A	RECEPT CATERING KITCHEN 166		22	
23		RECEPT CATERING KITCHEN 166	20 A	1			1200 VA / 1200 VA	1	20 A	RECEPT CATERING KITCHEN 166		24	
25		RECEPT CATERING KITCHEN 166	20 A	1	2400 VA / 456 VA			1	20 A	REFRIG CATERING KITCHEN 166	G	26	
27	G	FREEZER CATERING KITCHEN 166	15 A	1		780 VA / 1440 VA		1	15 A	HOT FOOD CABINET CATERING...	G	28	
29	G	ICE MAKER CATERING KITCHEN...	15 A	1			1356 VA / 1608 VA	1	20 A	MICROWAVE CATERING KITCHE...		30	
31	G	COFFEE BRW CAT KITCHEN 166	35 A	2	3050 VA / 600 VA			1	20 A	DRAIN TEMP KIT KIT 166		32	
33	--	--	--	--		3050 VA / 2988 VA		3	30 A	DISHWASHER CAT KITCHEN 166		34	
35		RECEPT BAR 165	20 A	1			180 VA / 2988 VA	--	--	--	--	36	
37	G	BEER DISPENSER BAR 165	15 A	1	792 VA / 2988 VA			--	--	--	--	38	
39		RECEPT BAR 167	20 A	1		180 VA / 180 VA		1	20 A	RECEPT BAR 167		40	
41		RECEPT BAR 165	20 A	1			180 VA / 180 VA	1	20 A	RECEPT BAR 165		42	
43		RECEPT CATERING KITCHEN 166	20 A	1	180 VA / 1000 VA			1	20 A	MOTORIZED SCREENS		44	
45	G	RECEPT MEN'S 153 HAND DRYERS	20 A	1		1860 VA / 120...		1	20 A	PROJECTOR BALLROOM 170		46	
47	G	RECEPT Room 153, 154 ACCESS	20 A	1			360 VA / 1200 VA	1	20 A	PROJECTOR BALLROOM 169		48	
49	G	RECEPT WOMEN'S 154 HAND DRY	20 A	1	1500 VA / 0 VA			1	20 A	SPARE		50	
51	G	RECEPT WOMEN'S 154 HAND DRY	20 A	1		1500 VA / 0 VA		1	20 A	SPARE		52	
53	G	RECEPT MEN'S 153 HAND DRYER	20 A	1		1500 VA / 0 VA		1	20 A	SPARE		54	
55		ACCESS CONTROL AV 164	20 A	1	400 VA / 0 VA			1	20 A	SPARE		56	
57		SPARE	20 A	1		0 VA / 0 VA		1	20 A	SPARE		58	
59		SPARE	20 A	1			0 VA / 0 VA	1	20 A	SPARE		60	
61		SPARE	20 A	1	0 VA / 0 VA			1	20 A	SPARE		62	
63		SPARE	20 A	1		0 VA / 0 VA		1	20 A	SPARE		64	
65		SPARE	20 A	1			0 VA / 0 VA	1	20 A	SPARE		66	
67		SPARE	20 A	1	0 VA / 0 VA			1	20 A	SPARE		68	
69		SPACE	--	1		0 VA / 0 VA		1	20 A	SPARE		70	
71		SPACE	--	1			0 VA / 0 VA	1	20 A	SPARE		72	
73		SPACE	--	1	0 VA / 0 VA			1	20 A	SPARE		74	
75		SPACE	--	1		0 VA / 0 VA		1	--	SPACE		76	
77		SPACE	--	1			0 VA / 0 VA	1	--	SPACE		78	
79		SPACE	--	1	0 VA / 0 VA			1	--	SPACE		80	
81		SPACE	--	1		0 VA / 0 VA		1	--	SPACE		82	
83		SPACE	--	1			0 VA / 0 VA	1	--	SPACE		84	
Total Load:					18000 VA		21438 VA		19292 VA				
Total Amps:					150 A		180 A		162 A				
Load Classification		Connected Load	Demand Factor	Estimated Demand	Panel Totals								
Kitchen Equipment - Non-Dwelling Unit		13636 VA	65.00%	8863 VA	Total Connected Load: 58730 VA								
Motor		8964 VA	125.00%	11205 VA	Total Estimated Demand: 48548 VA								
Other		180 VA	100.00%	180 VA									
RECEPT		25300 VA	69.76%	17650 VA	Total Connected Current: 163 A								
Equip.		8650 VA	100.00%	8650 VA	Total Est. Demand Current: 135 A								
REC		2000 VA	100.00%	2000 VA									
Notes: G = GFCI CIRCUIT BREAKER													

PANEL ID		PANEL DESCRIPTION											
LPHAA		NEW 3 PHASE PANELBOARD											
Location: ELECTRICAL 161		Voltage: 208/120 Wye				A.I.C. Rating: 22K							
Supply From: MDP-LHALL		Phase: 3				Mains Type: MCB							
Mounting: SURFACE		Wires: 4				Rating: 400 A							
Enclosure: NEMA 1		No. of Poles: 30				Bussing: COPPER							
CKT	Rev. No.	Circuit Description	Trip	Poles	A	B	C	Poles	Trip	Circuit Description	Rev. No.	CKT	
2		BALLROOMS 168 & 170 LTG	20 A	1	455 VA / 805 VA			1	20 A	VESTALOBVYCORP. LTG.		2	
3		BAR/CATERING/AV LTG 164-167	20 A	1		448 VA / 421 VA		1	20 A	RR / DRESS / OFFICE / SUPPORT...		4	
5		EXTERIOR CANOPY LIGHTING	20 A	1			534 VA / 325 VA	1	20 A	EXTERIOR PEDESTRIAN LTG		6	
7		LIGHTING DRESSING ROOM 156	20 A	1	449 VA / 191 VA			1	20 A	HANDRAIL LIGHTING		8	
9						0 VA / 720 VA		1	20 A	UPLIGHTS AT THE SKYRING		10	
11	SPARE		20 A	1			0 VA / 1020 VA	1	20 A	COLUMN UPLIGHTS		12	
13	SPARE		20 A	1	0 VA / 0 VA			1	20 A	SPARE		14	
15	SPARE		20 A	1		0 VA / 0 VA		1	20 A	SPARE		16	
17	SPACE	--	1				0 VA / 0 VA	1	--	SPACE		18	
19	SPACE	--	1		0 VA / 0 VA			1	--	SPACE		20	
21	SPACE	--	1			0 VA / 0 VA		1	--	SPACE		22	
23	SPACE	--	1				0 VA / 0 VA	1	--	SPACE		24	
25	SPACE	--	1		0 VA / 0 VA			1	--	SPACE		26	
27	SPACE	--	1			0 VA / 0 VA		1	--	SPACE		28	
29	SPACE	--	1				0 VA / 0 VA	1	--	SPACE		30	
Total Load:					1899 VA	1589 VA	1879 VA						
Total Amps:					16 A	13 A	16 A						
Load Classification			Connected Load		Demand Factor		Estimated Demand		Panel Totals				
Lighting			4054 VA		125.00%		5067 VA		Total Connected Load:			5386 VA	
LTG			1313 VA		125.00%		1641 VA		Total Estimated Demand:			6708 VA	
									Total Connected Current:			15 A	
									Total Est. Demand Current:			19 A	
Notes:													

TECHNOLOGY JUNCTION BOX LEGEND										
TYPE		FUNCTION	ENCLOSURE DIMENSIONS			ENCLOSURE DESCRIPTION	ENCLOSURE MAKE & MODEL	MOUNTING STYLE	REFERENCE DETAIL	LEGEND NOTES
SYM	STYLE		LENGTH	WIDTH	DEPTH					
F2	FLOOR	FLOOR BOX W/ AV TELECOM AND POWER	11 5/16"	15 1/8"	6"	FLOOR BOX	WIREMOLD EF88S	FLUSH WITH FINISHED FLOOR	2/T801	A, B
C1	WALL	CAMERA PULL BOX	4 11/16"	4 11/16"	2 1/8"	PULL BOX W/ RAISED TWO-DEVICE COVER	RACO 258 259 OR 265	96" AFF - FLUSH (UNO)	1/T801	-
D8	WALL	DISPLAY BOX W/ AV TELECOM AND POWER	10 7/8"	11 1/4"	3 7/8"	DISPLAY BOX	WIREMOLD EFSB4	FLUSH (UNO) - REFER TO ROOM DISPLAY SCHEDULE AND ELEVATIONS	3, 4/T801	C
L2	WALL	OUTDOOR LOUDSPEAKER PULL BOX	4 11/16"	4 11/16"	2 1/8"	OUTDOOR RATED PULL BOX	OUTDOOR RATED	90" AFF - FLUSH (UNO)	-	-
PS2	WALL	PARTITION SENSOR WALL BOX	4 11/16"	4 11/16"	2 1/8"	PULL BOX W/ FLAT COVER	RACO 258 259 OR 265	120" AFF - FLUSH (UNO)	-	-
R8	WALL	EQUIPMENT RACK PULL BOX W/ AV TELECOM AND POWER	12 3/8"	12 3/8"	4"	PULL BOX W/ PAINTED SCREW COVER	FSR WB-X2-GNG	PER PROJECT STANDARD OUTLET HEIGHT - FLUSH (UNO) - REFER TO ARCH. DRAWINGS	5, 6/T801	D
S2	WALL	PROJECTION SCREEN CONTROL SWITCH (DUAL)	4 11/16"	4 11/16"	2 1/8"	PULL BOX W/ RAISED TWO-DEVICE COVER	RACO 258 259 OR 265	PER PROJECT STANDARD SWITCH HEIGHT - FLUSH (UNO) - REFER TO ARCH. DRAWINGS	-	E, G
TP2	WALL	CONTROL PANEL W/ AV AND TELECOM	4 11/16"	4 11/16"	2 1/8"	PULL BOX W/ RAISED TWO-DEVICE COVER	RACO 258 259 OR 265	PER PROJECT STANDARD SWITCH HEIGHT - FLUSH (UNO) - REFER TO ARCH. DRAWINGS	-	-
W17	WALL	AV IO PANEL W/ AV TELECOM AND POWER	4 11/16"	10 7/16"	2 1/2"	PULL BOX W/ RAISED FOUR-DEVICE COVER	RACO 943	36" AFF - FLUSH (UNO)	7/T801	-
D41-1	CEILING	DISPLAY PULL BOX	4 11/16"	4 11/16"	2 1/8"	PULL BOX W/ FLAT COVER	RACO 258 259 OR 265	18" ABOVE ACCESSIBLE CEILING	-	-
IS1-3	CEILING	OCCUPANCY SENSOR	4 11/16"	4 11/16"	2 1/8"	PULL BOX W/ FLAT COVER	RACO 258 259 OR 265	SUSPENDED FROM DECK - FLUSH WITH CEILING	-	-
J6	CEILING	CONDUIT CONSOLIDATION PULL BOX	18"	18"	6"	PULL BOX (PUNCHED AS REQUIRED) W/ PAINTED SCREW COVER	HOFFMAN A-SE18X18X6NKN	18" ABOVE ACCESSIBLE CEILING	-	-
L11-1	CEILING	LOUDSPEAKER PULL BOX	4 11/16"	4 11/16"	2 1/8"	PULL BOX W/ FLAT COVER	RACO 258 259 OR 265	18" ABOVE ACCESSIBLE CEILING	1/T802	-
M1-1	CEILING	MICROPHONE PULL BOX	4 11/16"	4 11/16"	2 1/8"	PULL BOX W/ FLAT COVER	RACO 258 259 OR 265	18" ABOVE ACCESSIBLE CEILING	-	-
PJ1	CEILING	PROJECTOR LIFT	20"	36 9/32"	37 11/16"	MOTORIZED PROJECTOR LIFT ASSEMBLY	DRAPER SCISSOR SLX	SUSPENDED FROM DECK - FLUSH WITH CEILING	2/T802	E, F

TECHNOLOGY TELECOM JUNCTION BOX LEGEND										
TYPE		FUNCTION	ENCLOSURE DIMENSIONS			ENCLOSURE DESCRIPTION	ENCLOSURE MAKE & MODEL	MOUNTING STYLE	REFERENCE DETAIL	LEGEND NOTES
SYM	STYLE		LENGTH	WIDTH	DEPTH					
N1	FLOOR	TELECOM OUTLET - FLOOR	-	-	-	FLOOR DEVICE INDICATED BY BOX NUMBER	COORDINATE W/ ASSOCIATED FLOOR DEVICE	INSTALL IN FLOOR DEVICE PER MFR DIRECTIONS	2/T801	A, B, H
N2	WALL	TELECOM OUTLET - DISPLAY	-	-	-	WALL BOX INDICATED BY BOX NUMBER	COORDINATE W/ ASSOCIATED DISPLAY BOX	INSTALL IN DISPLAY BOX PER MFR DIRECTIONS	3, 4/T801	C, H
N3	WALL	TELECOM OUTLET - EQUIPMENT RACK	-	-	-	WALL BOX INDICATED BY BOX NUMBER	COORDINATE W/ ASSOCIATED EQUIPMENT RACK BOX	INSTALL IN EQUIPMENT RACK BOX PER MFR DIRECTIONS	5, 6/T801	D, H
N4	WALL	TELECOM OUTLET - STANDARD	4 11/16"	4 11/16"	2 1/8"	PULL BOX W/ RAISED ONE-DEVICE COVER	RACO 258 259 OR 265	PER PROJECT STANDARD OUTLET HEIGHT - FLUSH (UNO) - REFER TO ARCH. DRAWINGS	-	H, I
N6	WALL	TELECOM OUTLET - ABOVE COUNTER	4 11/16"	4 11/16"	2 1/8"	PULL BOX W/ RAISED ONE-DEVICE COVER	RACO 258 259 OR 265	PER PROJECT STANDARD COUNTER OUTLET HEIGHT - FLUSH (UNO) - REFER TO ARCH. DRAWINGS	-	H
N9	WALL	TELECOM OUTLET - IN RACEWAY	4 11/16"	4 11/16"	2 1/8"	PULL BOX W/ RAISED ONE-DEVICE COVER	RACO 258 259 OR 265	120" AFF - FLUSH	-	-
N10	WALL	TELECOM OUTLET - WAP	4 11/16"	4 11/16"	2 1/8"	PULL BOX W/ RAISED ONE-DEVICE COVER	RACO 258 259 OR 265	120" AFF - FLUSH	-	-
N11	WALL	TELECOM OUTLET - SECURITY CAMERA	4 11/16"	4 11/16"	2 1/8"	PULL BOX W/ RAISED ONE-DEVICE COVER	RACO 258 259 OR 265	120" AFF - FLUSH	-	H
N13	WALL	TELECOM OUTLET - UTILITY	4 11/16"	4 11/16"	2 1/8"	PULL BOX W/ RAISED ONE-DEVICE COVER	RACO 258 259 OR 265	COORDINATE WITH APPLICABLE TRADE	-	H
N14	WALL	TELECOM PULL BOX - TOUCH OR SCHEDULING PANEL	-	-	-	WALL BOX INDICATED BY BOX NUMBER	COORDINATE W/ ASSOCIATED TOUCH OR SCHEDULING PANEL BOX	INSTALL NETWORK JACK WITHIN ASSOCIATED TOUCH OR SCHEDULING PANEL BOX	-	H
N15	WALL	TELECOM OUTLET - AV IO PANEL	-	-	-	AV IO PANEL INDICATED BY BOX NUMBER	COORDINATE W/ ASSOCIATED AV IO PANEL	INSTALL IN AV IO PANEL PER MFR DIRECTIONS	7/T801	H
N16	WALL	TELECOM OUTLET - POLE-MOUNT CAMERA	4 11/16"	4 11/16"	2 1/8"	PULL BOX	RACO 258 259 OR 265	REFER TO ARCH. DRAWINGS	-	-
N21-1	CEILING	TELECOM OUTLET - DISPLAY	4 11/16"	4 11/16"	2 1/8"	PULL BOX W/ BLANK COVER	RACO 258 259 OR 265	18" ABOVE ACCESSIBLE CEILING	-	H
N23-1	CEILING	TELECOM OUTLET - WAP	4 11/16"	4 11/16"	2 1/8"	PULL BOX W/ BLANK COVER	RACO 258 259 OR 265	18" ABOVE ACCESSIBLE CEILING	-	H
N24-1	CEILING	TELECOM OUTLET - SECURITY CAMERA	4 11/16"	4 11/16"	2 1/8"	PULL BOX W/ BLANK COVER	RACO 258 259 OR 265	18" ABOVE ACCESSIBLE CEILING	-	H
N24-3	CEILING	TELECOM OUTLET - SECURITY CAMERA	4 11/16"	4 11/16"	2 1/8"	PULL BOX W/ RAISED ONE-DEVICE COVER	RACO 258 259 OR 265	SUSPENDED FROM DECK - FLUSH WITH CEILING	-	H

TECHNOLOGY POWER LEGEND										
TYPE		FUNCTION	VOLTS	AMPS	NEMA	DESCRIPTION	ADDITIONAL REQUIREMENTS	MOUNTING STYLE	REFERENCE DETAIL	LEGEND NOTES
SYM	STYLE									
P1	FLOOR	POWER RECEPTACLE - FLOOR DEVICE	120	20	5-20R	DUPLEX RECEPTACLE INSIDE FLOOR DEVICE	-	INSTALL IN FLOOR DEVICE PER MFR DIRECTIONS	2/T801	A, B, J
P2	WALL	POWER RECEPTACLE - DISPLAY	120	20	5-20R	DUPLEX RECEPTACLE INSIDE DISPLAY BOX	-	INSTALL IN DISPLAY BOX PER MFR DIRECTIONS	3, 4/T801	C, J
P3	WALL	POWER RECEPTACLE - EQUIPMENT RACK	120	20	5-20R	DUPLEX RECEPTACLE INSIDE EQUIPMENT RACK BOX	-	INSTALL IN EQUIPMENT RACK BOX PER MFR DIRECTIONS	5, 6/T801	D, J
P7	WALL	POWER RECEPTACLE - TECHNOLOGY RACK	120	20	5-20R	DOUBLE DUPLEX RECEPTACLE (DUAL CIRCUIT)	TWO DEDICATED CIRCUITS	PER PROJECT STANDARD OUTLET HEIGHT - FLUSH (UNO) - REFER TO ARCH. DRAWINGS	-	J
P15	WALL	POWER RECEPTACLE - AV IO PANEL	120	20	5-20R	DUPLEX RECEPTACLE INSIDE AV IO PANEL	-	INSTALL IN AV IO PANEL PER MFR DIRECTIONS	7/T801	J
P16	WALL	POWER CIRCUIT - ACCESS CONTROL PANEL	120	20	-	HARDWIRED POWER CIRCUIT DIRECT TO ACCESS CONTROL PANEL	DEDICATED CIRCUIT	REFER TO PLANS & ELEVATIONS	-	J
P17	WALL	POWER RECEPTACLE - CONVENIENCE DUPLEX	120	20	5-20R	DUPLEX RECEPTACLE	-	PER PROJECT STANDARD OUTLET HEIGHT - FLUSH (UNO) - REFER TO ARCH. DRAWINGS	-	J
P18	WALL	POWER RECEPTACLE - TELECOM RACK	208	30	L6-30R	TWIST-LOCK RECEPTACLE	DEDICATED CIRCUIT	MOUNT TO CABLE RUNWAY ABOVE EQUIPMENT RACK	-	J
P22	CEILING	POWER CIRCUIT - MOTORIZED PROJECTION SCREEN	120	20	-	WORKBOX W/ POWER CIRCUIT	-	TERMINATE AT PROJECTION SCREEN PER MFR INSTRUCTIONS	-	G, J
P23	CEILING	POWER CIRCUIT - MOTORIZED PROJECTOR LIFT	120	20	-	WORKBOX W/ POWER CIRCUIT	DEDICATED CIRCUIT	TERMINATE AT PROJECTOR LIFT PER MFR INSTRUCTIONS	2/T802	E, G, J

TELECOM CABLING LEGEND					
TYPE	CAT6A	FIBER	2-16AWG	REFERENCE DETAIL	NOTES
A	1	0	0	1/T901	-
B	2	0	0	1/T901	-
C	3	0	0	1/T901	-
D	4	0	0	1/T901	-
E	6	0	0	1/T901	-
F	0	4	2	1/T901	HARD WIRED TO FIBER TRANSCEIVER & POWER
G	1	0	0	1/T901	DIRECT CONNECT


TECHNOLOGY LEGEND NOTES	
<p>[A] FLOOR BOXES AND FLOOR PENETRATIONS: VERIFY EXACT LOCATION, COVER STYLE AND FINISH WITH ARCHITECT PRIOR TO INSTALLATION. PROVIDE ON-GRADE OR FIRE-RATED VERSION FLOOR BOXES AS REQUIRED.</p>	
<p>[B] F2(N1, P1) FLOOR BOX CONFIGURATION: WIREMOLD EVOLUTION SERIES EF88S-OG FLOOR BOX WITH FINISHED COVER. VERIFY COVER STYLE AND FINISH WITH ARCHITECT PRIOR TO ORDERING. INCLUDED COMPONENTS: TEMPORARY CONSTRUCTION COVER, TUNNEL SYSTEM, TWO REMOVABLE MODULES, CABLE MANAGEMENT GUIDES, MOUNTING CLAMPS AND LEVELING SUPPORT LEGS. PROVIDE AS REQUIRED: POWER RECEPTACLES, COMMUNICATION JACKS, MOUNTING BRACKETS, DEVICE PLATES, BLANK DEVICE PLATES, DIVIDER PLATES, AND OTHER ACCESSORIES AS NEEDED. CONFIGURE BOX ACCORDING TO DETAILS. VERIFY EXACT LOCATION WITH ARCHITECT PRIOR TO INSTALLATION.</p>	
<p>[C] D8(N2, P2) FLAT PANEL DISPLAY BOX CONFIGURATION: WIREMOLD EVOLUTION SERIES EFSB4 FLAT PANEL DISPLAY WALL BOX. VERIFY COVER COLOR WITH ARCHITECT PRIOR TO ORDERING. INCLUDED COMPONENTS: TUNNEL, DEVICE MODULES, TRIM FLANGE, AND DECORATIVE COVER. PROVIDE AS REQUIRED: POWER RECEPTACLES, COMMUNICATION JACKS, DEVICE PLATES, BLANK DEVICE PLATES, KNOCKOUT PLATES, AND OTHER ACCESSORIES AS NEEDED. CONFIGURE BOX ACCORDING TO DETAILS.</p>	
<p>[D] R8(N3, P3) LARGE CAPACITY WALL BOX CONFIGURATION: FSR WB-X2-GNG LARGE CAPACITY WALL BOX WITH LOCKING COVER. VERIFY COVER COLOR AND STYLE WITH ARCHITECT PRIOR TO ORDERING. INCLUDED COMPONENTS: INTERNAL BRACKETS, CENTER DIVIDERS, AND MOUNTING BRACKETS. PROVIDE AS REQUIRED: POWER RECEPTACLES, COMMUNICATION JACKS, DEVICE PLATES, DEVICE BLANK PLATES, AND OTHER ACCESSORIES AS NEEDED. CONFIGURE BOX ACCORDING TO DETAILS.</p>	
<p>[E] PROJECTOR LIFT: DRAPER SCISSOR LIFT SLX SCISSOR LIFT WITH ENOUGH TRAVEL TO EXTEND TO 6" AFF. PROVIDE OPTIONAL CEILING CLOSURE PANEL OR OPTIONAL ENVIRONMENTAL AIR SPACE HOUSING AS REQUIRED, AS WELL AS CEILING FINISH KIT. COORDINATE FINISH WITH ARCHITECT PRIOR TO ORDERING.</p>	
<p>[F] CEILING SUSPENDED VIDEO PROJECTOR: THE LOCATION OF THE AUDIOVISUAL, POWER AND TELECOM JUNCTION BOXES IN RELATION TO THE PROJECTION SCREEN IS CRITICAL. FOR VIDEO PROJECTOR INFRASTRUCTURE LAYOUT INFORMATION REFER TO THE "TYPICAL PROJECTION SCREEN DETAIL" AND OTHER REFERENCED DETAILS.</p>	
<p>[G] PROJECTION SCREEN LOW VOLTAGE CONTROL SYSTEM: PROVIDE AC LINE VOLTAGE CONNECTION TO SCREEN CONTROL INTERFACE BUILT INTO MOTORIZED PROJECTION SCREEN HOUSING PER MANUFACTURER'S INSTRUCTION. PROVIDE LOW VOLTAGE WIRING CONNECTION FROM SCREEN CONTROL INTERFACE TO WALL MOUNTED PROJECTION SCREEN WALL SWITCH PER MANUFACTURER'S INSTRUCTION.</p>	
<p>[H] TELECOM OUTLETS AND ASSOCIATED CONDUITS: CONDUIT MUST BE PROVIDED FOR ALL TELECOM JUNCTION BOXES. SEE THE "TELECOM TYPICAL CONDUIT RISER" FOR CONDUIT REQUIREMENTS BY TELECOM JUNCTION BOX TYPE. REFER TO THE TELECOM PLANS FOR THE LOCATIONS OF JUNCTION BOXES AND FLOOR BOXES, AND THE "TELECOM CABLING LEGEND" FOR OUTLET CONFIGURATION REQUIREMENTS. TELECOM CABLING, OUTLETS AND COVER PLATES PROVIDED BY THE STRUCTURED CABLING SYSTEMS CONTRACTOR.</p>	
<p>[I] POWER RECEPTACLES ADJACENT TO INDICATED TELECOM WALL OUTLETS: INDICATED TELECOM WALL OUTLETS SHALL HAVE A DUPLEX POWER RECEPTACLE LOCATED WITHIN 36" OF THE TELECOM WALL OUTLET. IDEALLY, THE TELECOM OUTLET BOX WILL BE MOUNTED TO ONE SIDE OF A STUD, AND THE POWER BOX TO THE OPPOSITE SIDE OF THE STUD.</p>	
<p>[J] POWER RECEPTACLES AND DIRECT CIRCUIT CONNECTIONS: TECHNICAL POWER RECEPTACLES AND DIRECT CIRCUIT CONNECTIONS, INCLUDING THOSE WITHIN FLOOR BOXES, WALL BOXES, OR CEILING BOXES, ARE PROVIDED BY ELECTRICAL CONTRACTOR AND APPEAR ON THE ELECTRICAL DRAWINGS. TECHNICAL POWER APPEARS ON THE TECHNOLOGY INFRASTRUCTURE DRAWINGS FOR COORDINATION AND LOCATION PURPOSES. THE LOCATION OF TECHNICAL POWER IN RELATION TO OTHER TECHNOLOGY INFRASTRUCTURE MAY BE CRITICAL. REFER TO THE ELECTRICAL DRAWINGS FOR COMPLETE POWER LAYOUTS AND CIRCUITING DETAILS.</p>	

REVISIONS		
10/27/2026	A2	ADDENDUM 02

10/27/2026 BID AND PERMIT SET	
Drawn By	TGAUNTNER
Designer	JFISHMAN, TROBINETTE
Reviewer	DCHITTY, KKERSTETTER
Manager	CKRETOVIC



Hard copy is intended to be 24"x36" when plotted. Scale(s) indicated and graphic quality may not be accurate for any other size.

PLOT INFO: 10/26/2026 12:59:05 PM Autodesk Docs://2500281 - Van Buren Twp Lake House2026_T_2500281.rvt

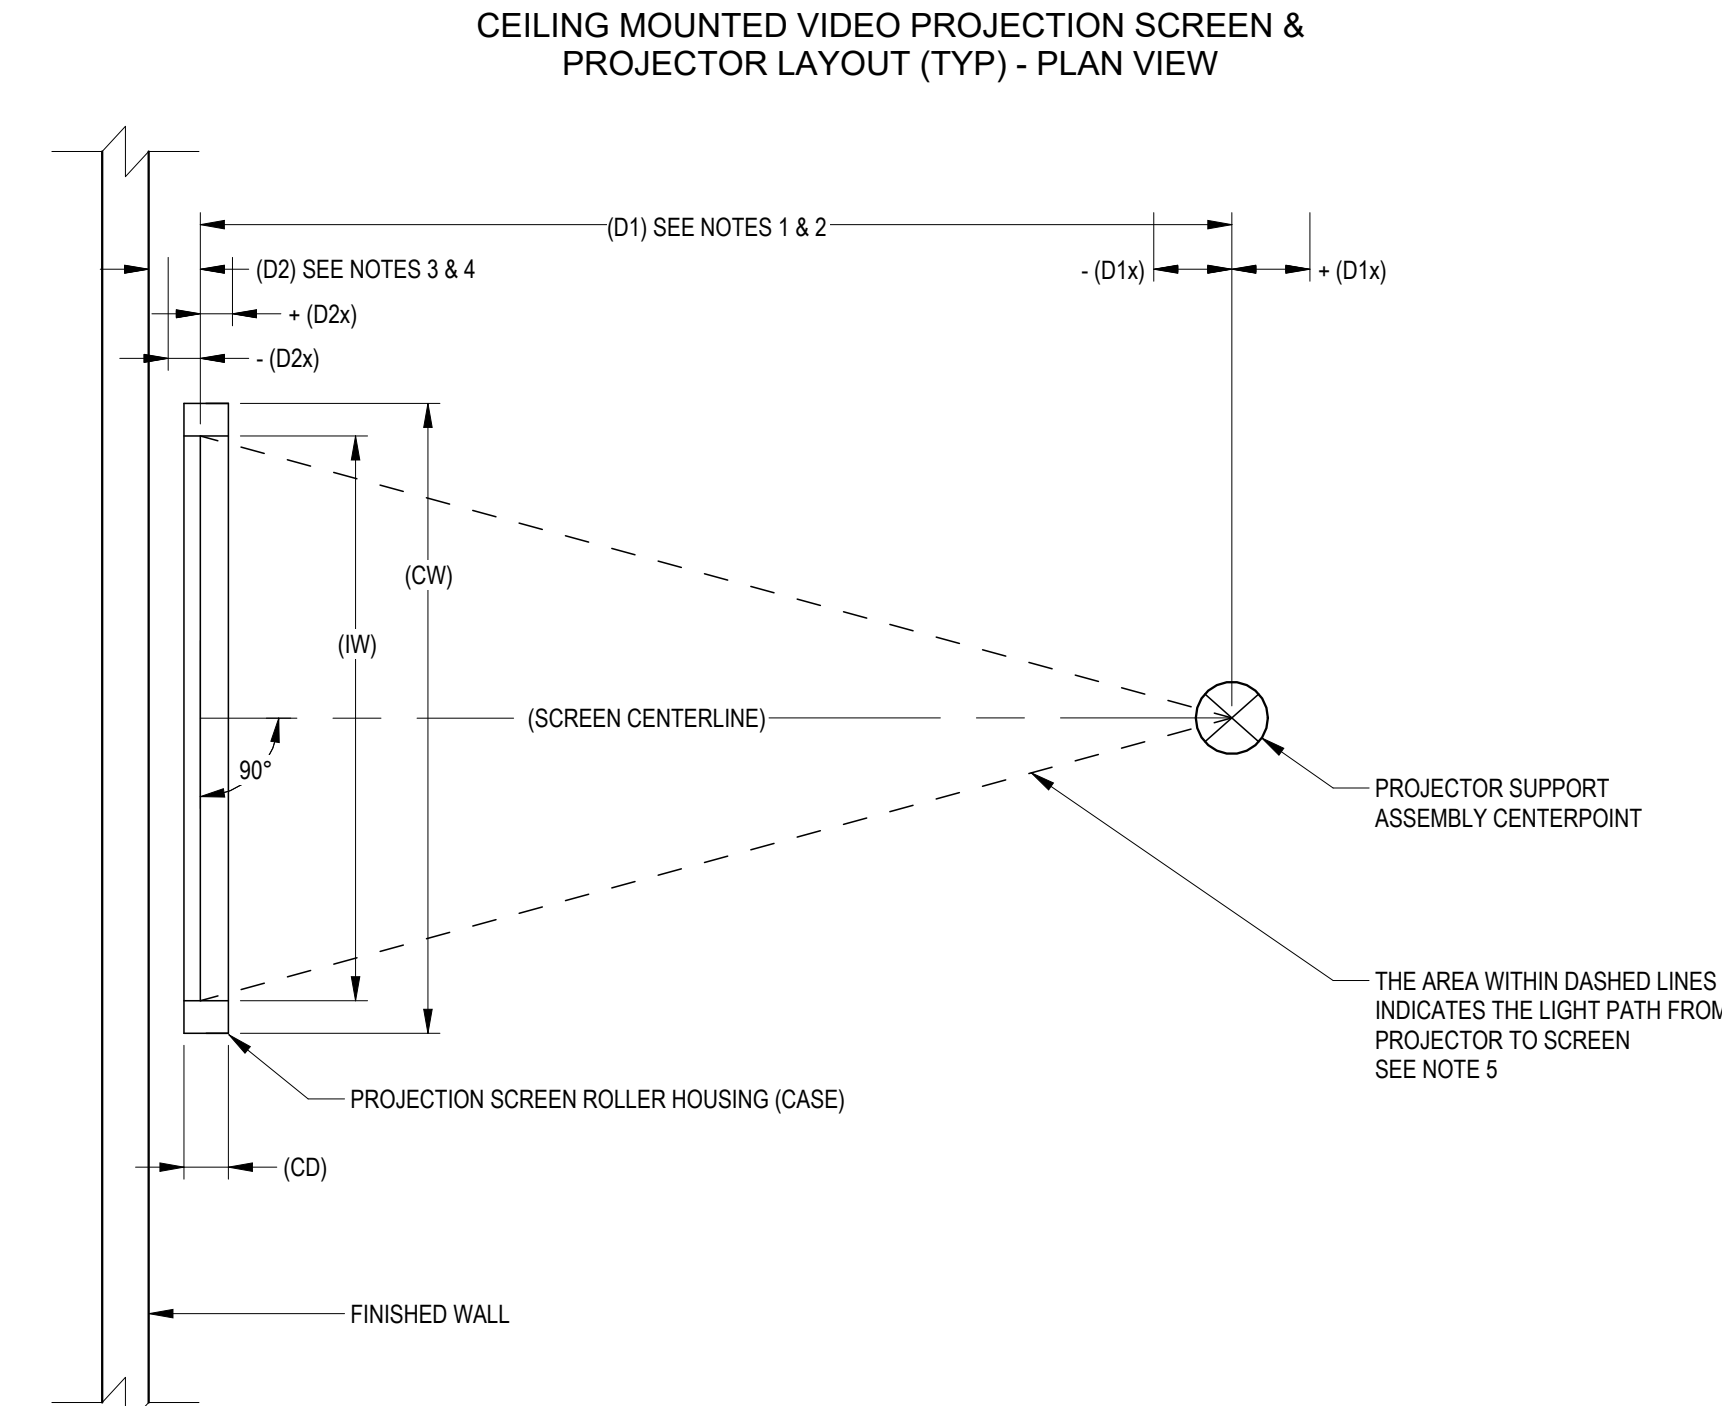

PROJECTION SCREEN / VIDEO PROJECTOR RELATIONSHIP NOTES

- [D1] – CRITICAL DISTANCE: D1 IS THE DISTANCE FROM THE PROJECTION SCREEN SURFACE TO THE CENTER OF THE PROJECTOR CEILING MOUNT ASSEMBLY.
 - IMPORTANT: IF DISTANCE D2 IS ADJUSTED, D1 MUST REMAIN CONSTANT.
- [D1X] – ALLOWABLE D1 VARIANCE: D1X DEFINES THE PERMISSIBLE ± VARIANCE FOR D1 TO ACCOMMODATE STRUCTURAL OR OTHER OBSTRUCTIONS.
 - EXAMPLE: IF D1 = 300" AND D1X = 10", THE PROJECTOR CEILING MOUNT CENTER MAY BE LOCATED BETWEEN 290" AND 310" FROM THE SCREEN SURFACE ALONG THE SCREEN CENTERLINE.
- [D2] – MINIMUM PROJECTION WALL CLEARANCE: D2 IS THE MINIMUM DISTANCE FROM THE PROJECTION WALL TO THE PROJECTION SCREEN SURFACE.
 - IF D2 MUST INCREASE BEYOND D2 + D2X TO AVOID OBSTRUCTIONS, CONTACT THE CONSULTANT FOR DIRECTION.
- [D2X] – ALLOWABLE D2 VARIANCE: D2X DEFINES THE PERMISSIBLE ± VARIANCE FOR D2.
 - EXAMPLE: IF D2 = 6" AND D2X = 2", THE SCREEN SURFACE MAY BE LOCATED BETWEEN 4" AND 8" FROM THE PROJECTION WALL ON THE SCREEN CENTERLINE.
- CLEAR PROJECTION PATH: THE PROJECTOR MUST HAVE AN UNOBSTRUCTED VIEW OF THE ENTIRE SCREEN IMAGE AREA AT ALL TIMES.
- [BLACK DROP] – FIELD VERIFICATION REQUIRED: THE BLACK DROP AMOUNT LISTED IN THE ROOM PROJECTION SCREEN SCHEDULE IS A DESIGN ESTIMATE.
 - FIELD-VERIFY EACH SCREEN PRIOR TO SUBMITTAL.
 - REQUIRED BLACK DROP (BD) = (RHAFF) – (HAFF + IH)
 - RHAFF: ROLLER HOUSING ELEVATION ABOVE FINISHED FLOOR
 - IHAFF: BOTTOM OF IMAGE HEIGHT ABOVE FINISHED FLOOR
 - IH: IMAGE HEIGHT
 - EXCESS BLACK DROP REMAINING ON THE ROLLER WHEN THE SCREEN IS DEPLOYED SHOULD NOT EXCEED ONE WRAP.
 - IF ACTUAL CEILING HEIGHT DIFFERS FROM DRAWINGS, THE SPECIFIED IMAGE HEIGHT ABOVE FINISHED FLOOR (IHAFF) GOVERNS.
- POWER JUNCTION BOX LOCATION: LOCATE THE PROJECTION SCREEN POWER JUNCTION BOX ON THE SAME SIDE AS THE SCREEN'S ELECTRICAL CONNECTIONS (VARIES BY SCREEN TYPE). VERIFY LOCATION PRIOR TO INSTALLATION.

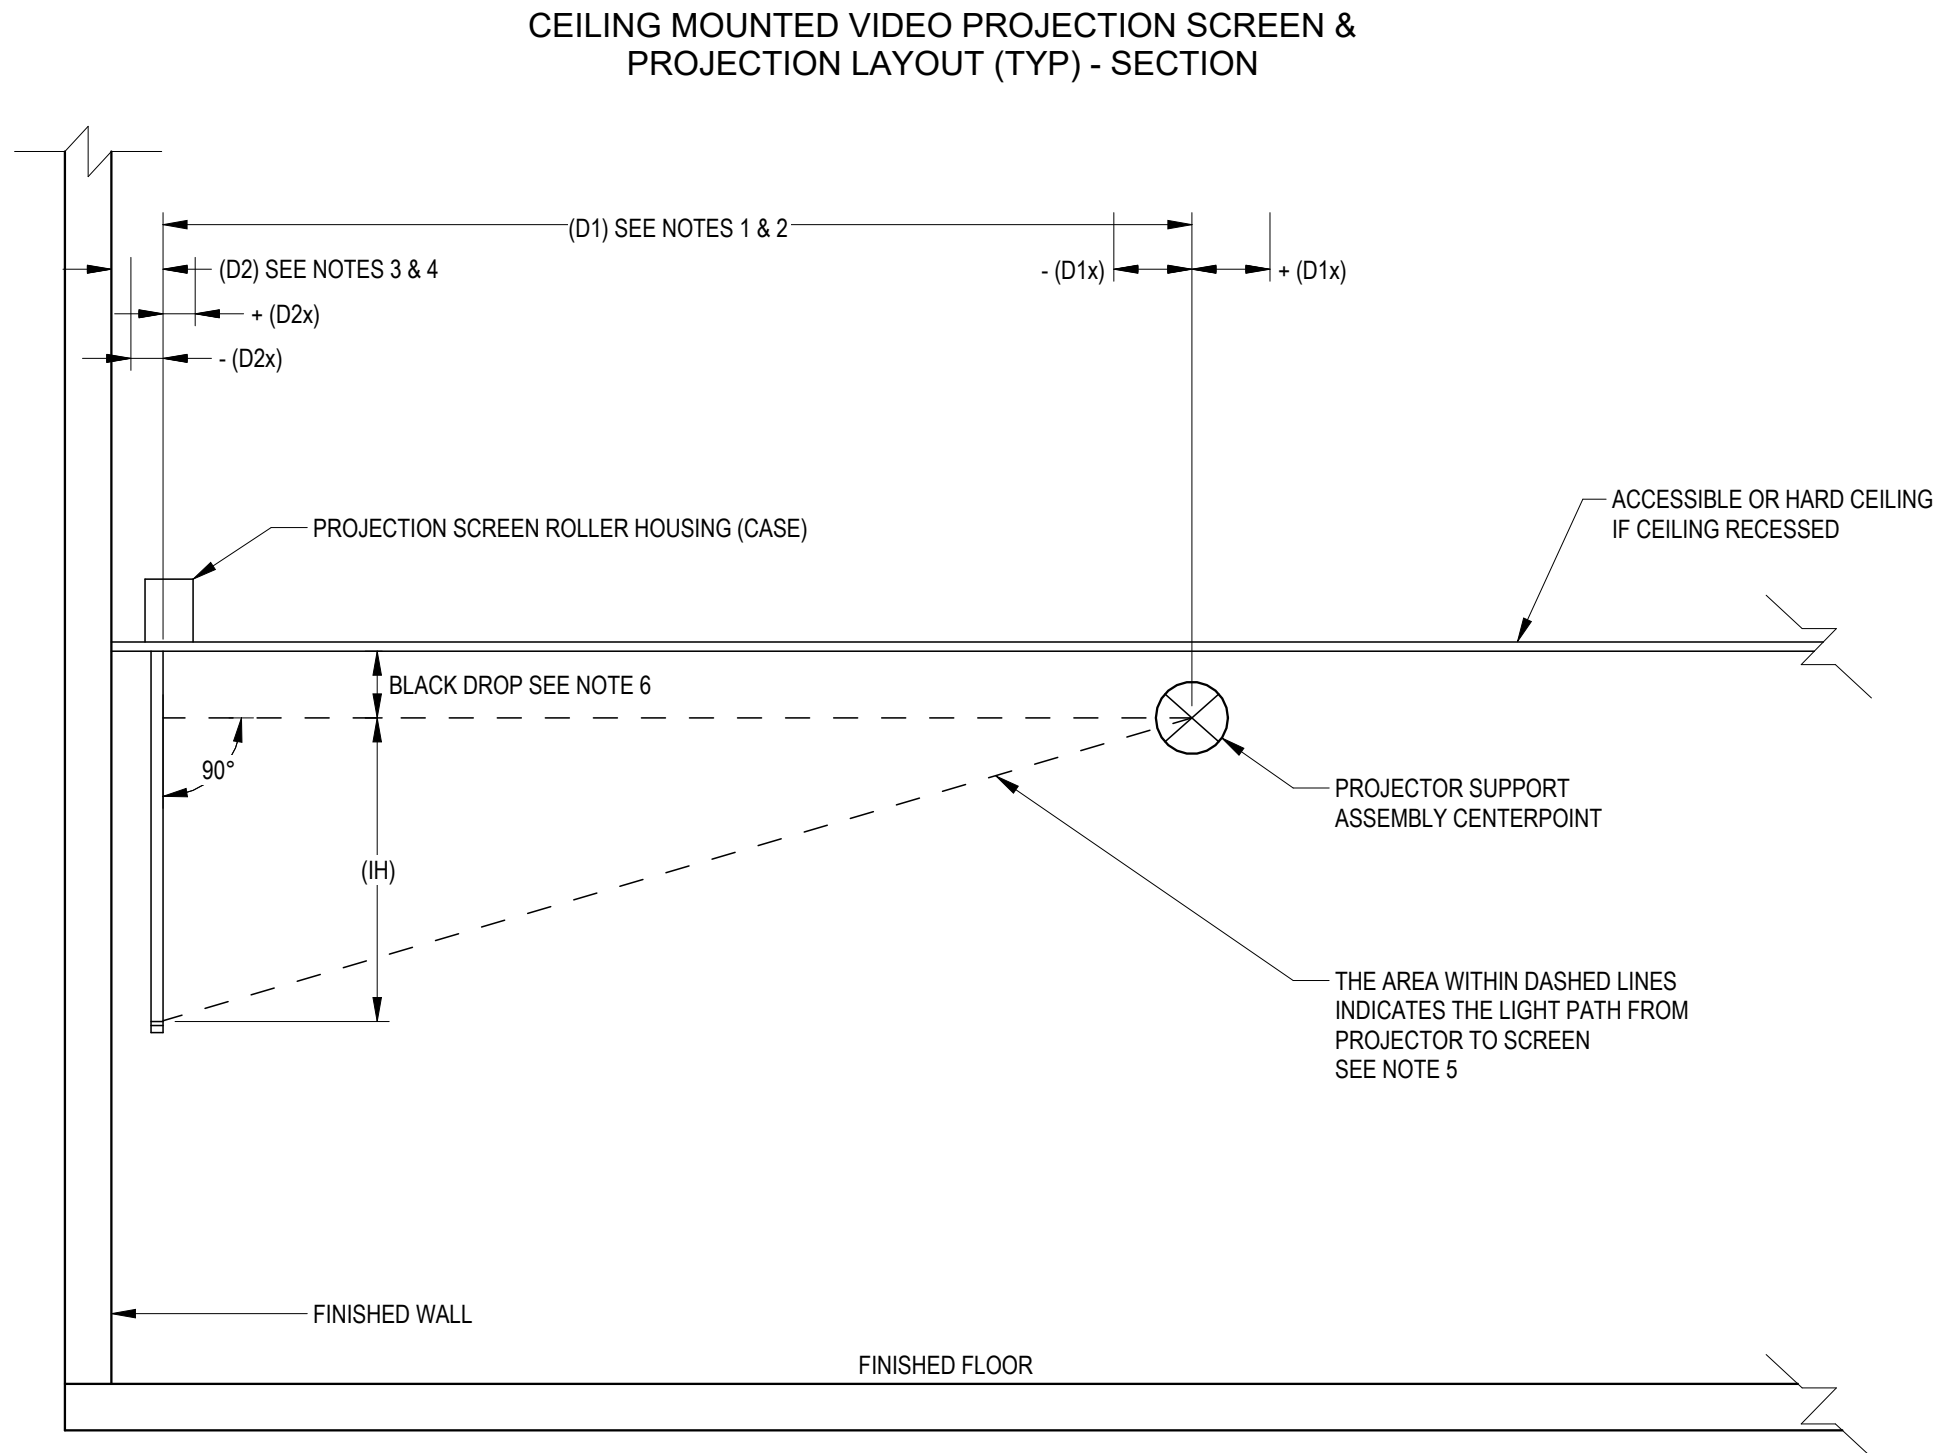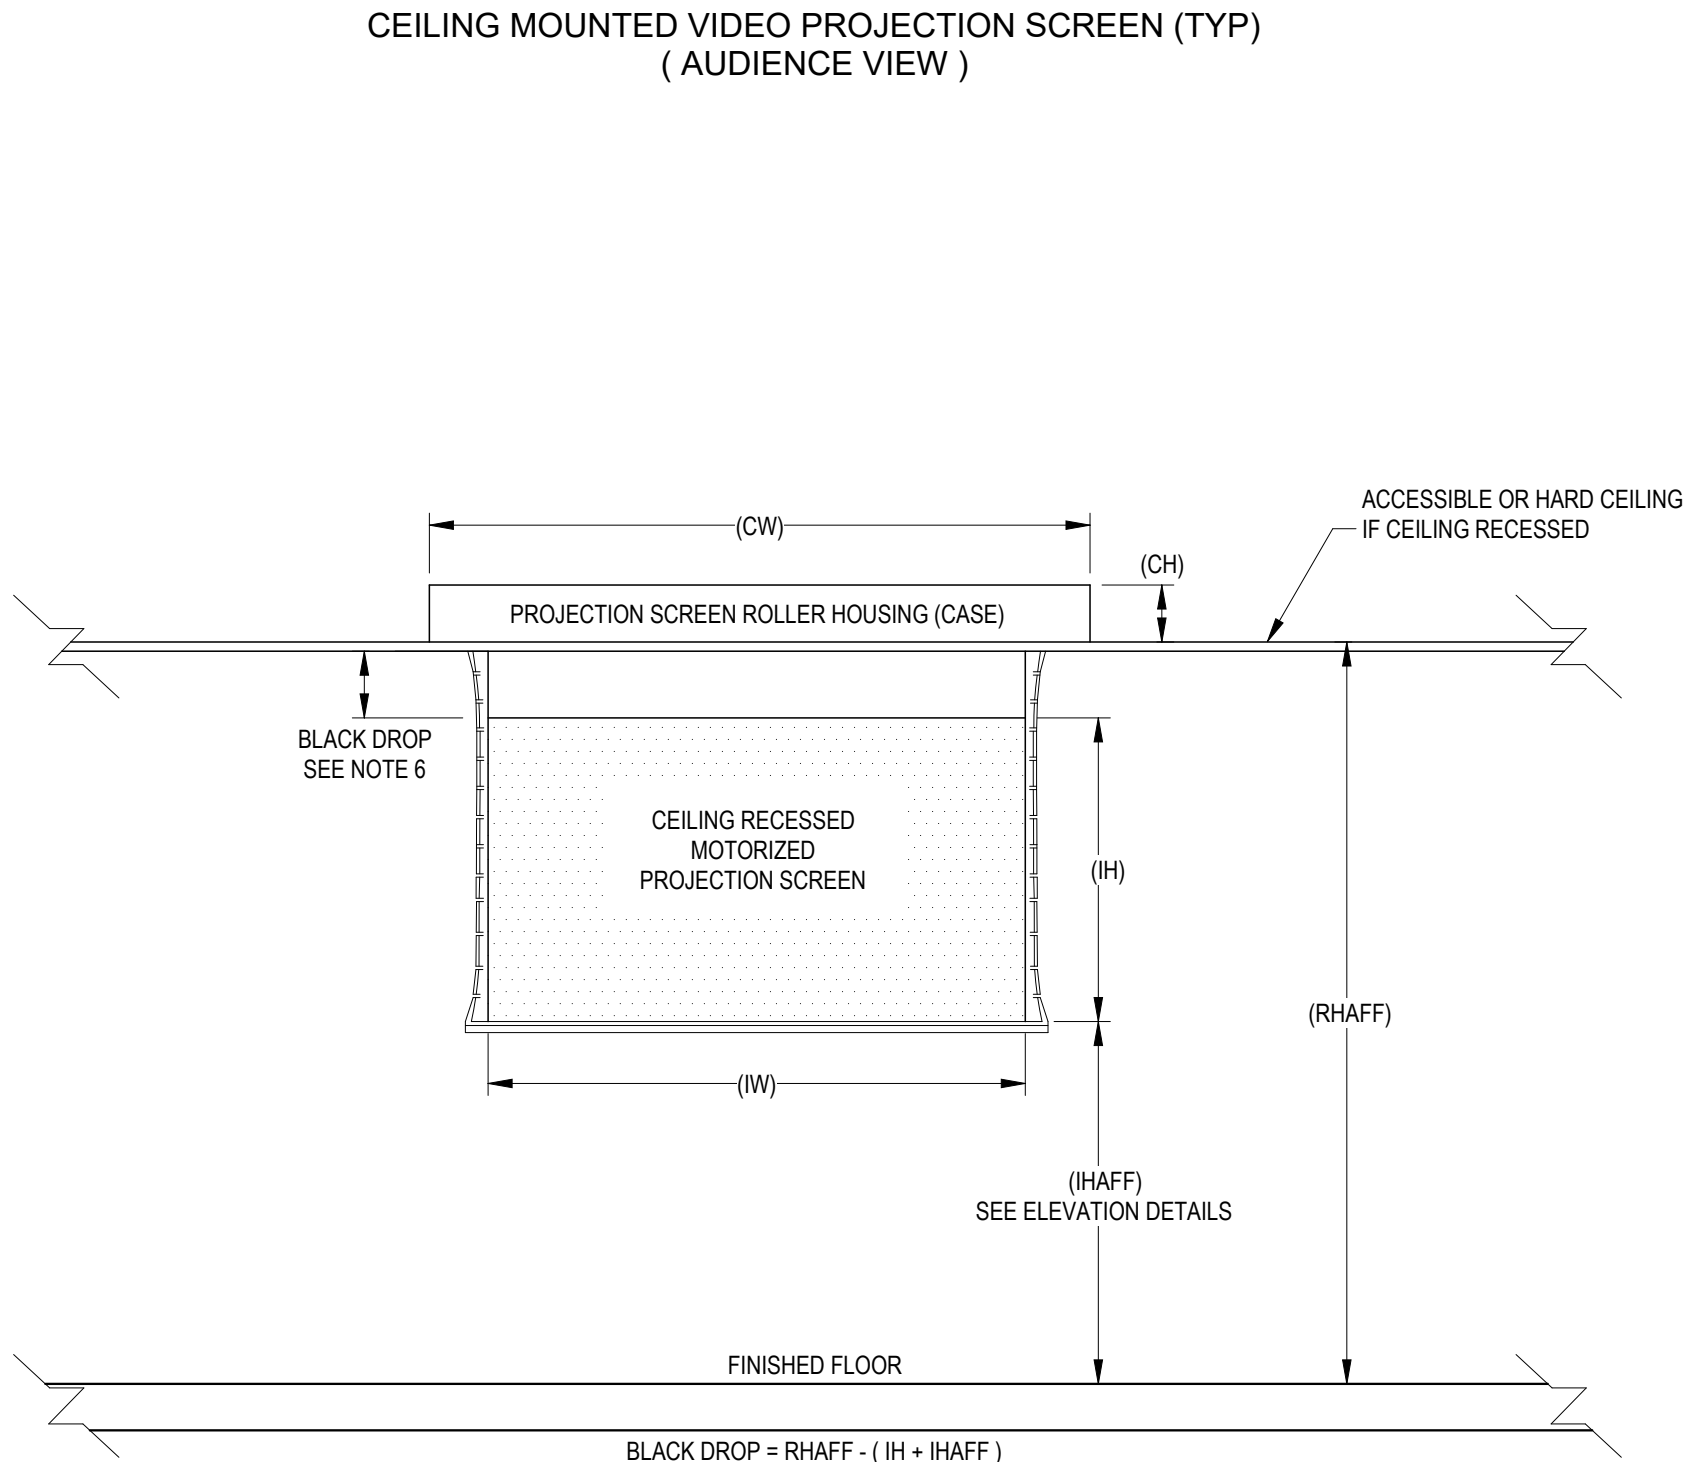

PROJECTION SCREEN TYPE LEGEND												
ALL DIMENSIONS IN INCHES / WEIGHT IN POUNDS												
TYPE	IMAGE SIZE		CASE SIZE			WEIGHT (lbs)	INSTALLATION	OPERATION	MAKE & MODEL	IMAGE SURFACE MATERIAL	CONTROL	CASE PROVIDED BY
	HEIGHT (IH)	WIDTH (IW)	HEIGHT (CH)	WIDTH (CW)	DEPTH (CD)							
A	65"	116"	7 15/16"	132 1/2"	7 3/4"	100	CEILING MOUNTED - FLUSH	MOTORIZED	DA-LITE TENSIONED ADVANTAGE WITH SIGHTLINE	PARALLAX STRATOS 1.0	INTERNAL LVC	GENERAL CONTRACTOR

DISPLAY TYPE LEGEND							
ALL DIMENSIONS IN INCHES / WEIGHT IN POUNDS							
TYPE	NOMINAL IMAGE DIAGONAL	NOMINAL CASE SIZE			NOMINAL WEIGHT (lbs)	BACKING	
		HEIGHT (H)	WIDTH (W)	DEPTH (D)		HEIGHT (H)	WIDTH (W)
55	55"	29"	50"	4"	60	24"	48"
65	65"	34"	59"	4"	77	24"	48"
98	98"	49"	87"	4"	183	48"	96"

ROOM PROJECTION SCREEN SCHEDULE									
PROJECTION SCREEN / VIDEO PROJECTOR RELATIONSHIP IS CRITICAL (SEE GRAPHIC - TYPICAL PROJECTION SCREEN / VIDEO PROJECTOR RELATIONSHIP)									
ROOM NUMBER	QTY	SCREEN TYPE	SCREEN				PROJECTOR MOUNT		
			BOTTOM OF IMAGE AFF	BLACK DROP (EST)	DISTANCE [D2]	DISTANCE [D2x]	DISTANCE [D1]	DISTANCE [D1x]	
169	1	A	54"	6"	10"	0"	203"	18"	
170	1	A	54"	6"	10"	0"	203"	18"	

ROOM DISPLAY SCHEDULE				
VERTICAL AND HORIZONTAL CENTERLINE OF THE DISPLAY AND BACK BOX MAY DIFFER. REFER TO ELEVATIONS.				
ROOM NUMBER	DISPLAY QTY	DISPLAY TYPE	ELEV AFF OC	COMMENTS
104	1	55	108"	
105	2	98	72"	
118	1	65	66"	

Van Buren Charter Township

Van Buren Township, MI

The Lakeside Park

REVISIONS		
10/27/2026	A2	ADDENDUM 02

10/12/2026 BID AND PERMIT SET	
Drawn By	TGAUNTNER
Designer	JFISHMAN, TROBINETTE
Reviewer	DCHITTY, KKERSTETTER
Manager	CKRETOVIC

Hard copy is intended to be 24"x36" when plotted. Scale(s) indicated and graphic quality may not be accurate for any other size.


PROJECT NO.
2500281

SHEET NO.

T003


©Copyright 2026
All Rights Reserved

PLOT INFO: 10/26/2026 12:59:07 PM Autodesk Docs://2500281 - Van Buren Twp Lake House2026_T_2500281.rvt

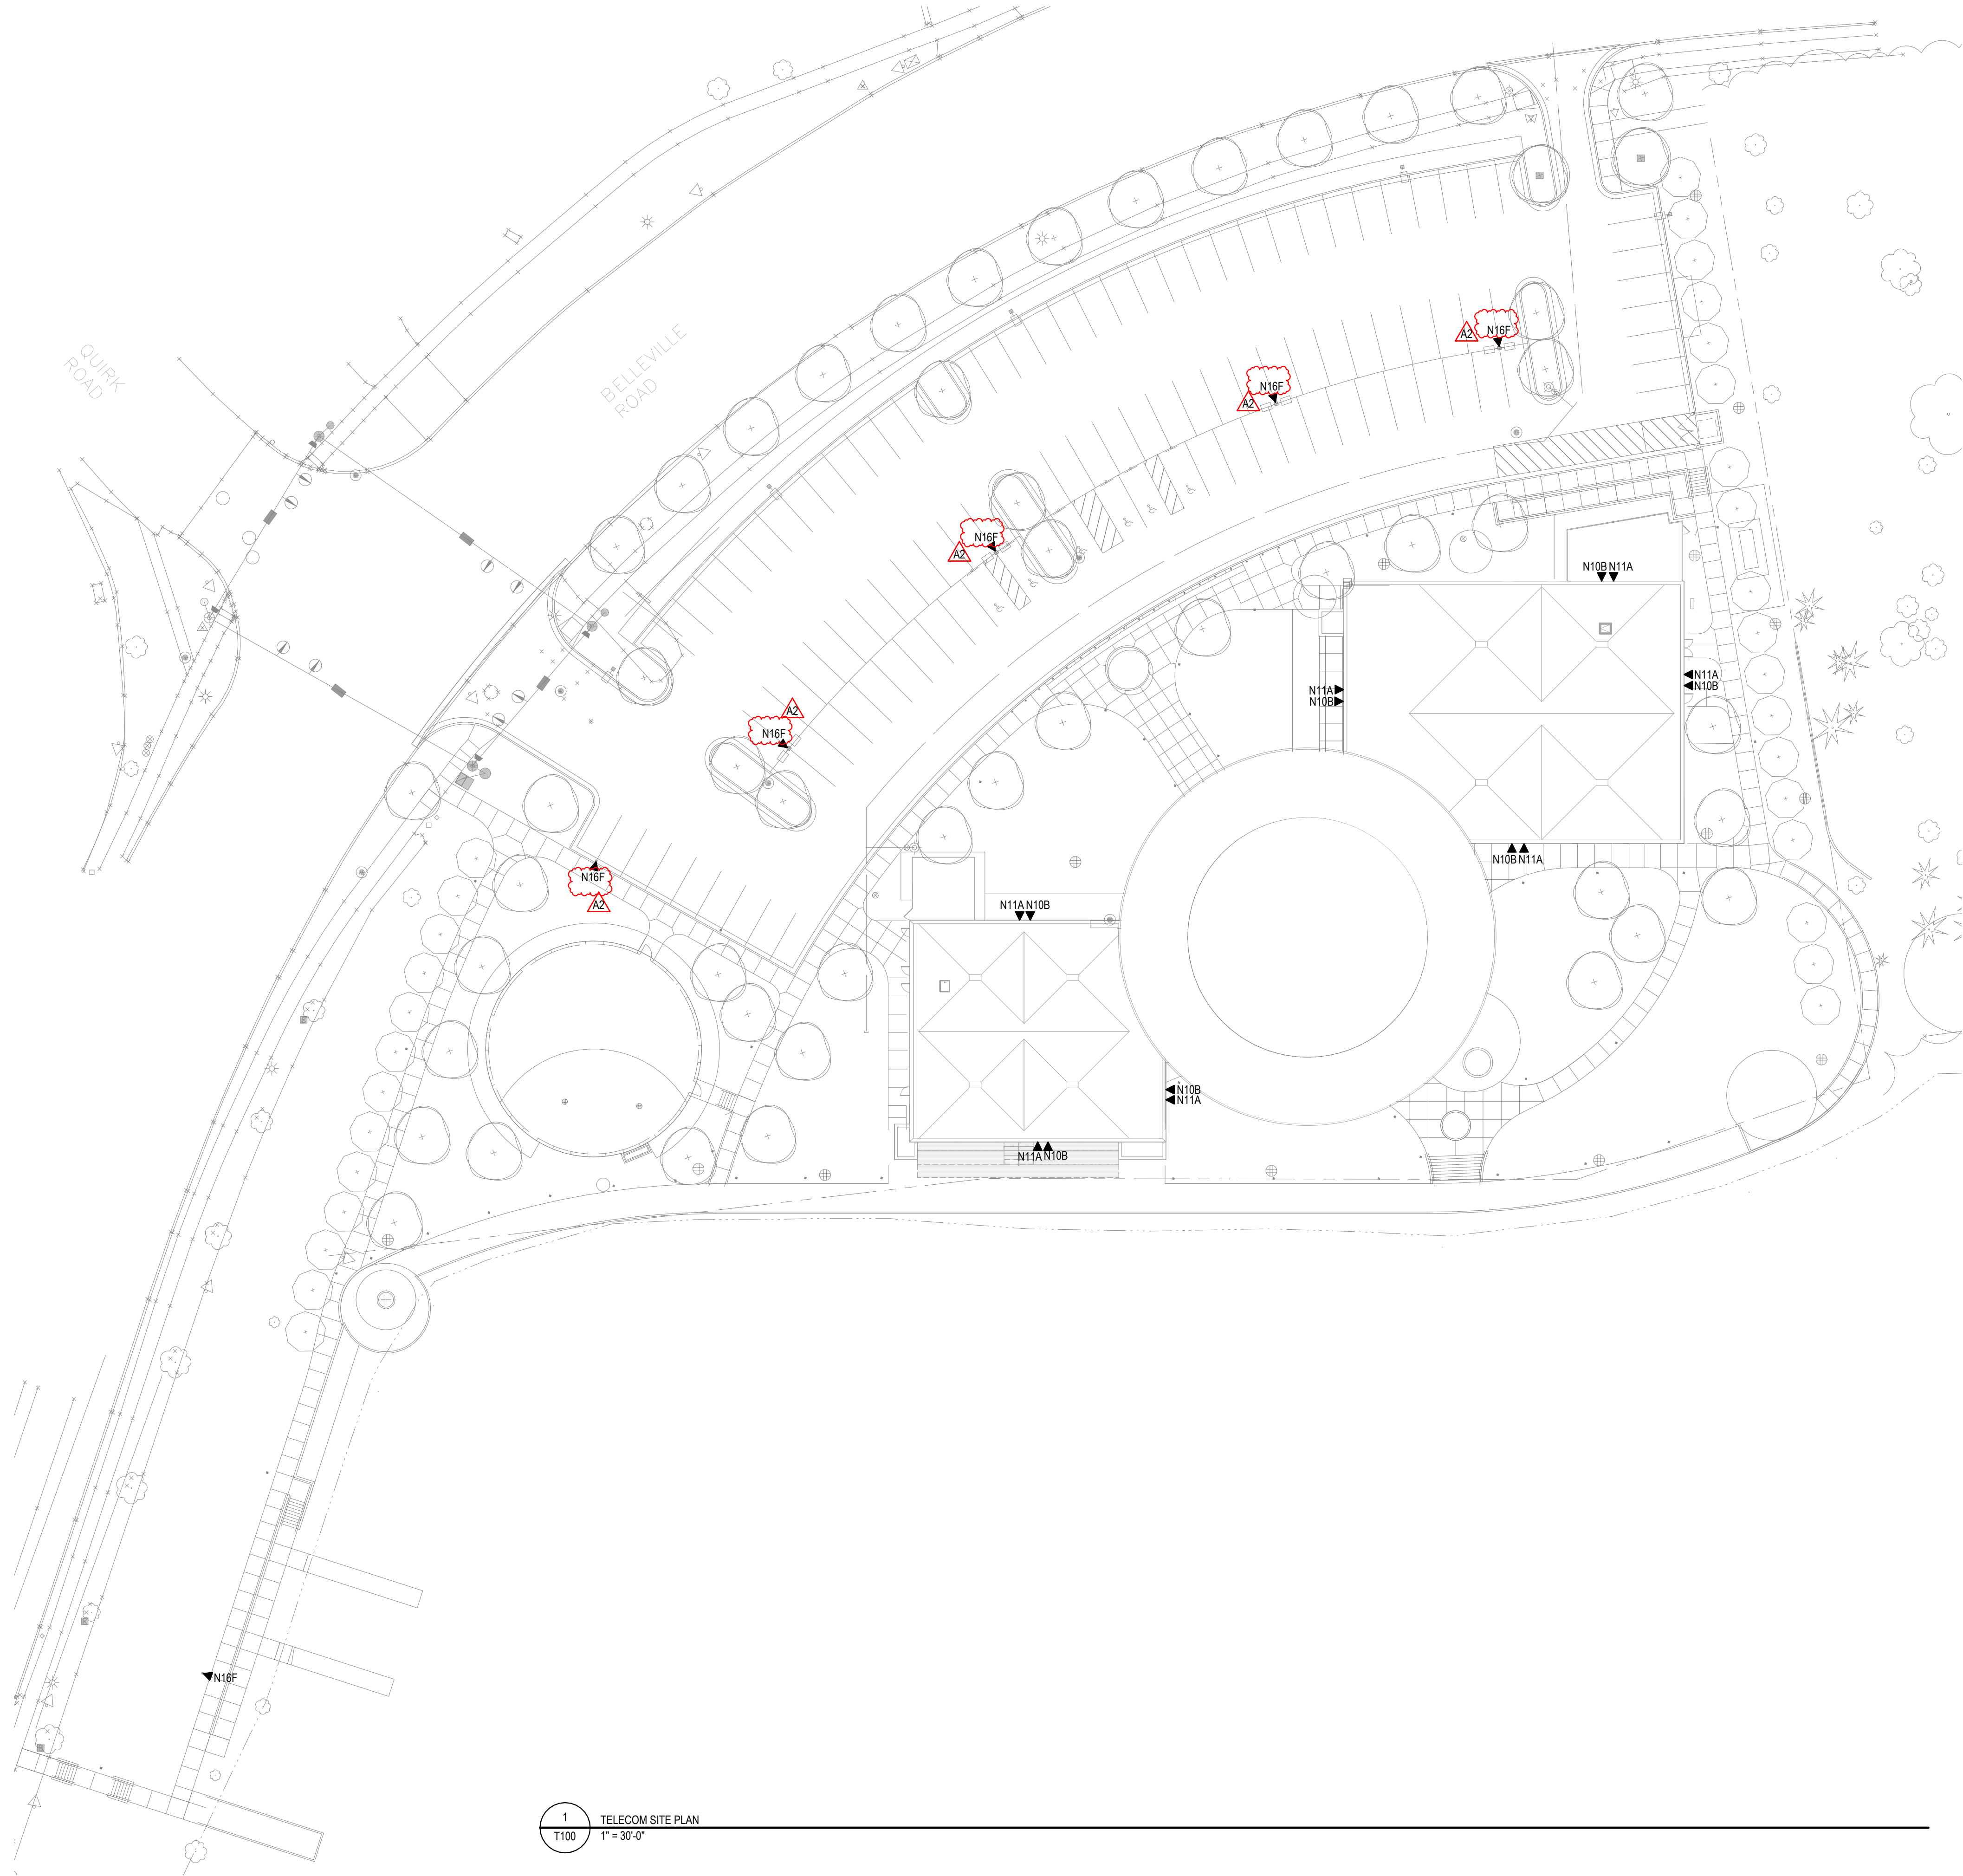

1 TELECOM SITE PLAN
T100 1" = 30'-0"

KEY PLAN

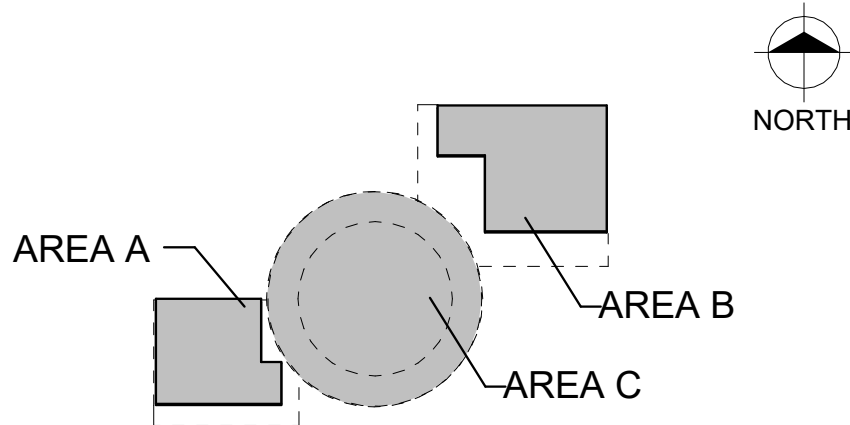

Van Buren Charter Township

Van Buren Township, MI

The Lakeside Park


REVISIONS		
10/27/2026	A2	ADDENDUM 02

Drawn By	TGAUNTNER
Designer	JFISHMAN, TROBINETTE
Reviewer	DCHITTY, KKERSTETTER
Manager	CKRETOVIC

Hard copy is intended to be 24"x36" when plotted. Scale(s) indicated and graphic quality may not be accurate for any other size.

PROJECT NO.	2500281
SHEET NO.	T100
©Copyright 2026 All Rights Reserved	

PLOT INFO: 10/26/2026 12:59:09 PM Autodesk Docs://2500281 - Van Buren Twp Lake House2026_T_2500281.rvt

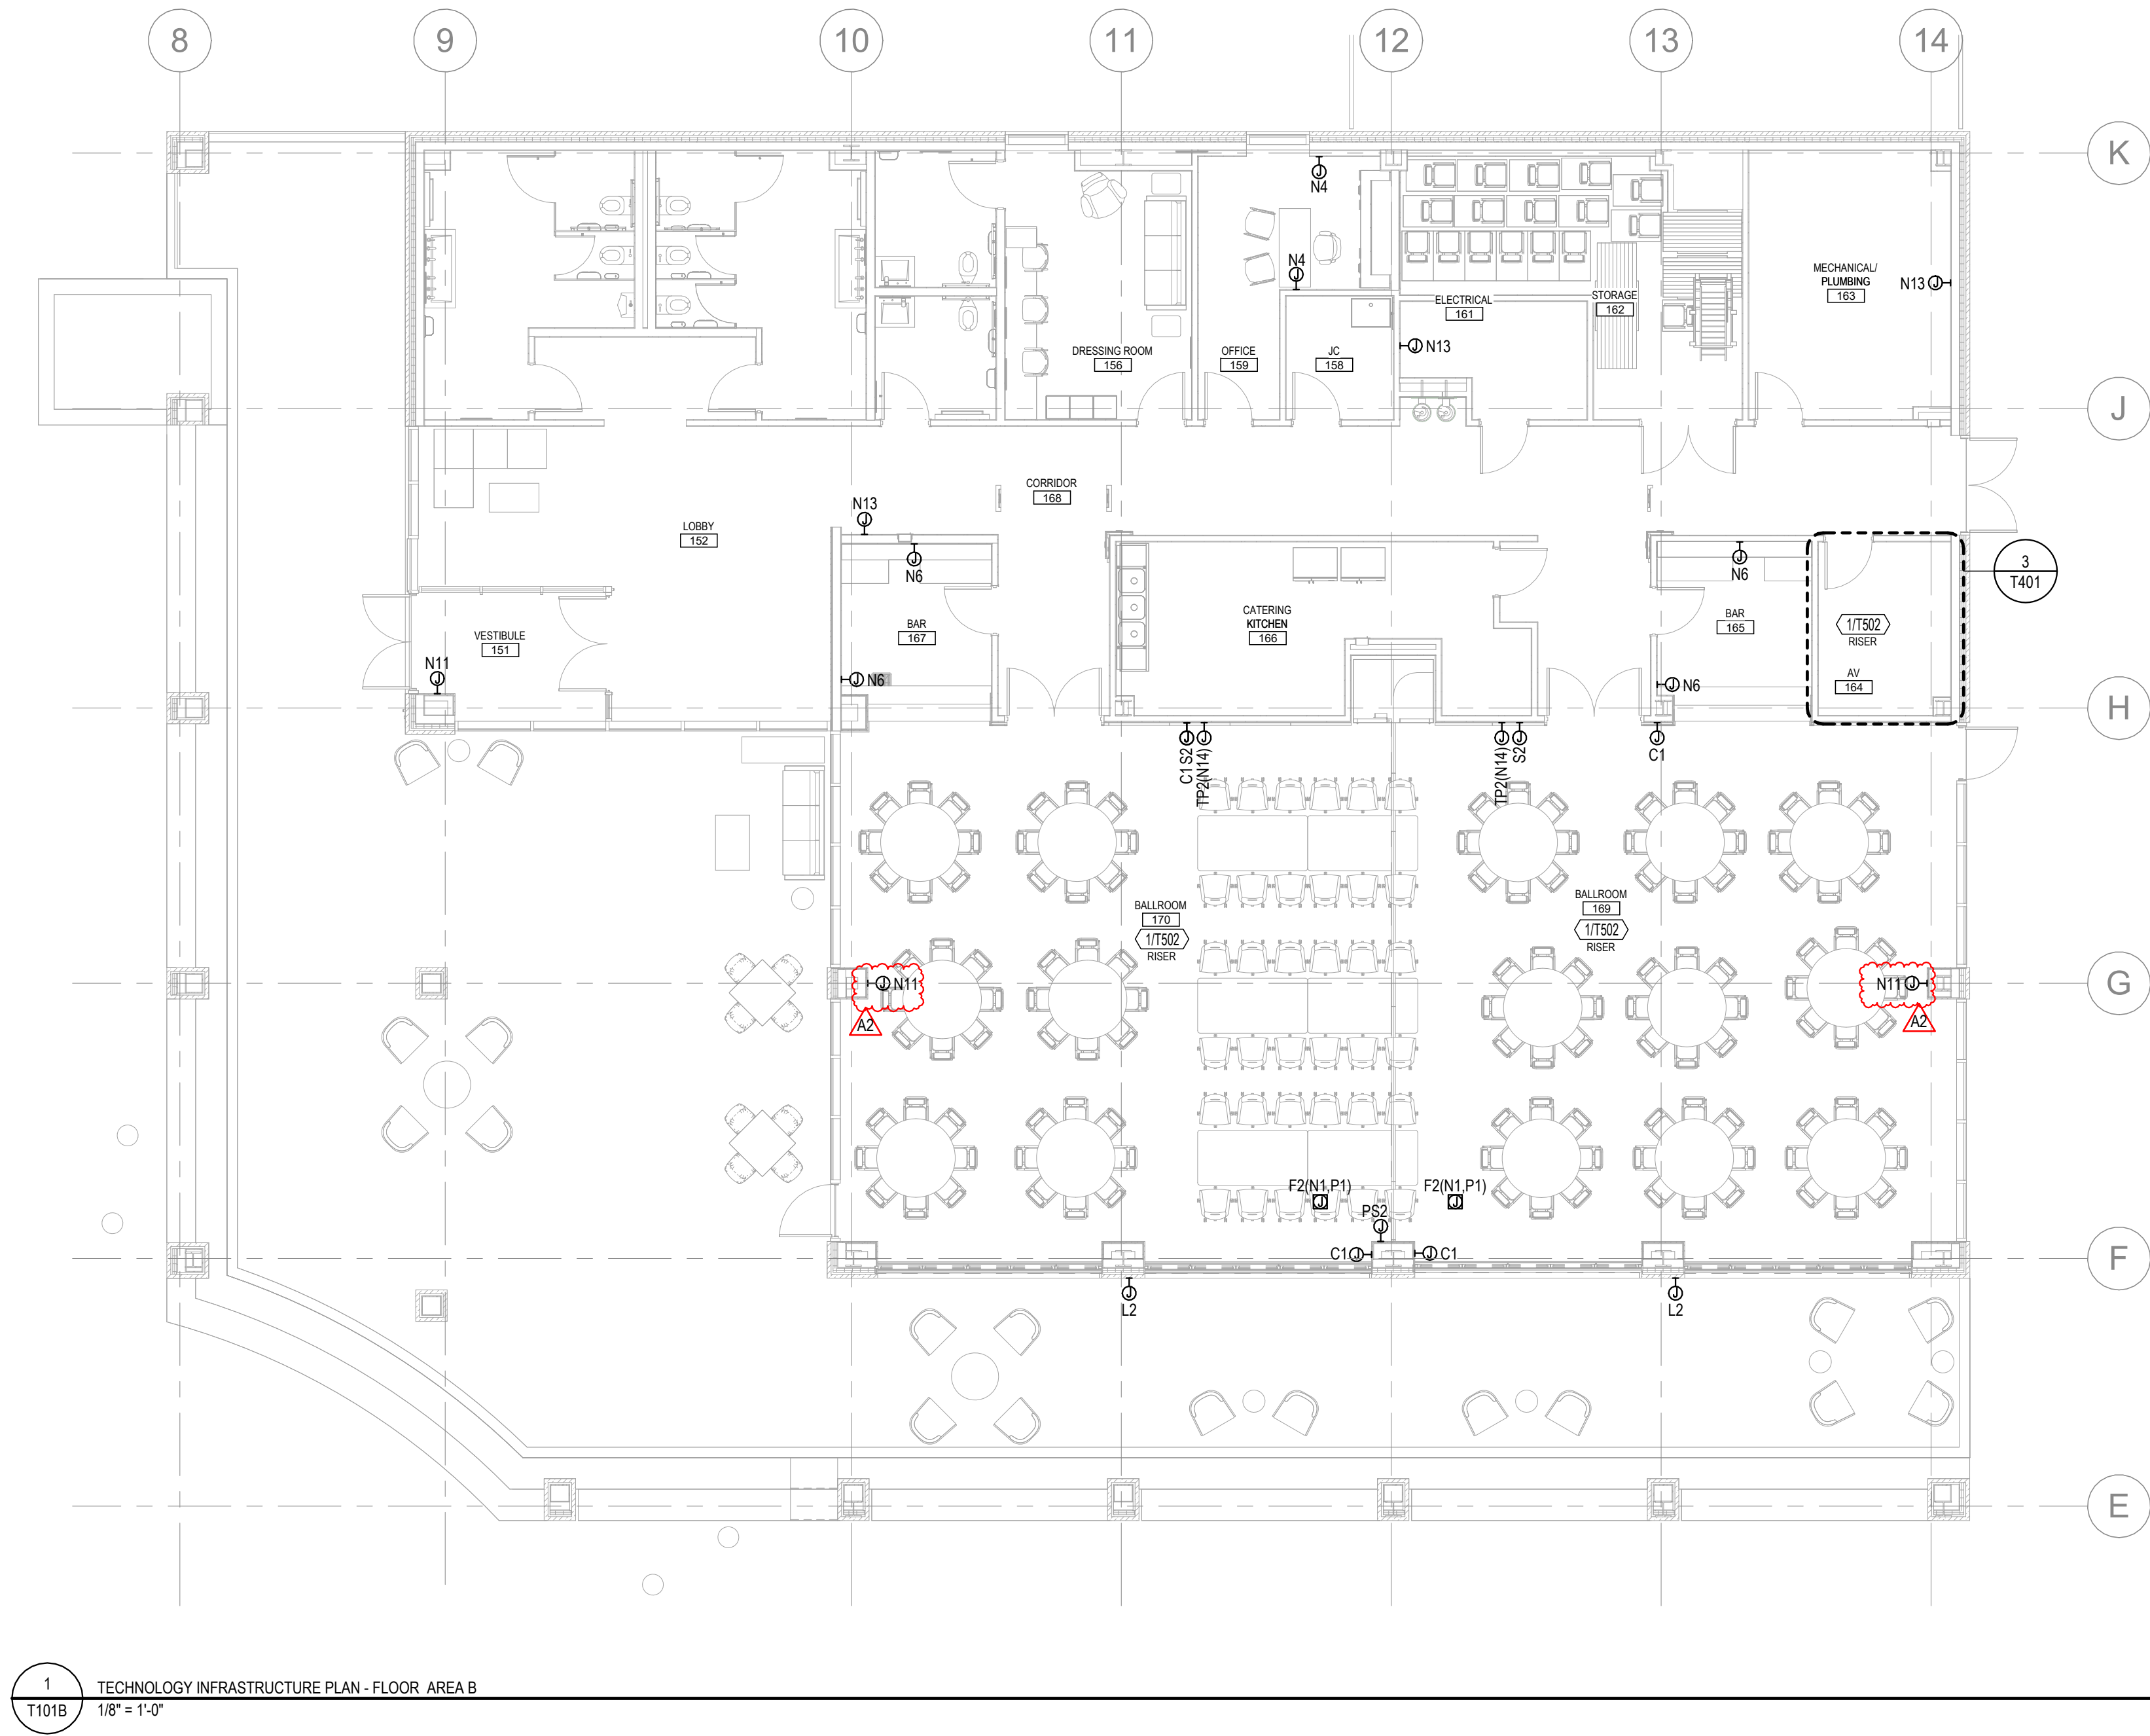


1 TECHNOLOGY INFRASTRUCTURE PLAN - FLOOR AREA B
T101B 1/8" = 1'-0"

SHEET NOTES - INFRASTRUCTURE

- 1 REFER TO SHEET T001 FOR ALL TECHNOLOGY INFRASTRUCTURE GENERAL NOTES, LEGENDS, ABBREVIATIONS, AND SHEET INDEX.
- 2 REFER TO SHEET T002 & T003 FOR ALL INFRASTRUCTURE SCHEDULES AND LEGENDS

KEY PLAN

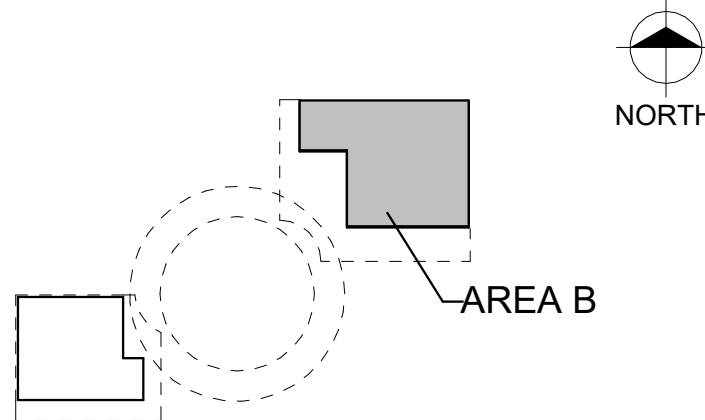

Van Buren Charter Township

Van Buren Township, MI

The Lakeside Park

REVISIONS

10/27/2026	A2	ADDENDUM 02
------------	----	-------------

10/12/2026	BID AND PERMIT SET
------------	--------------------

Drawn By	TGAUNTNER
Designer	JFISHMAN, TROBINETTE
Reviewer	DCHITTY, KKERSTETTER
Manager	CKRETOVIC

Hard copy is intended to be 24"x36" when plotted. Scale(s) indicated and graphic quality may not be accurate for any other size.

PROJECT NO.


2500281

SHEET NO.

T101B

©Copyright 2026
All Rights Reserved


PLOT INFO: 10/26/2026 12:59:14 PM Autodesk Docs://2500281 - Van Buren Twp Lake House2026_T_2500281.rvt

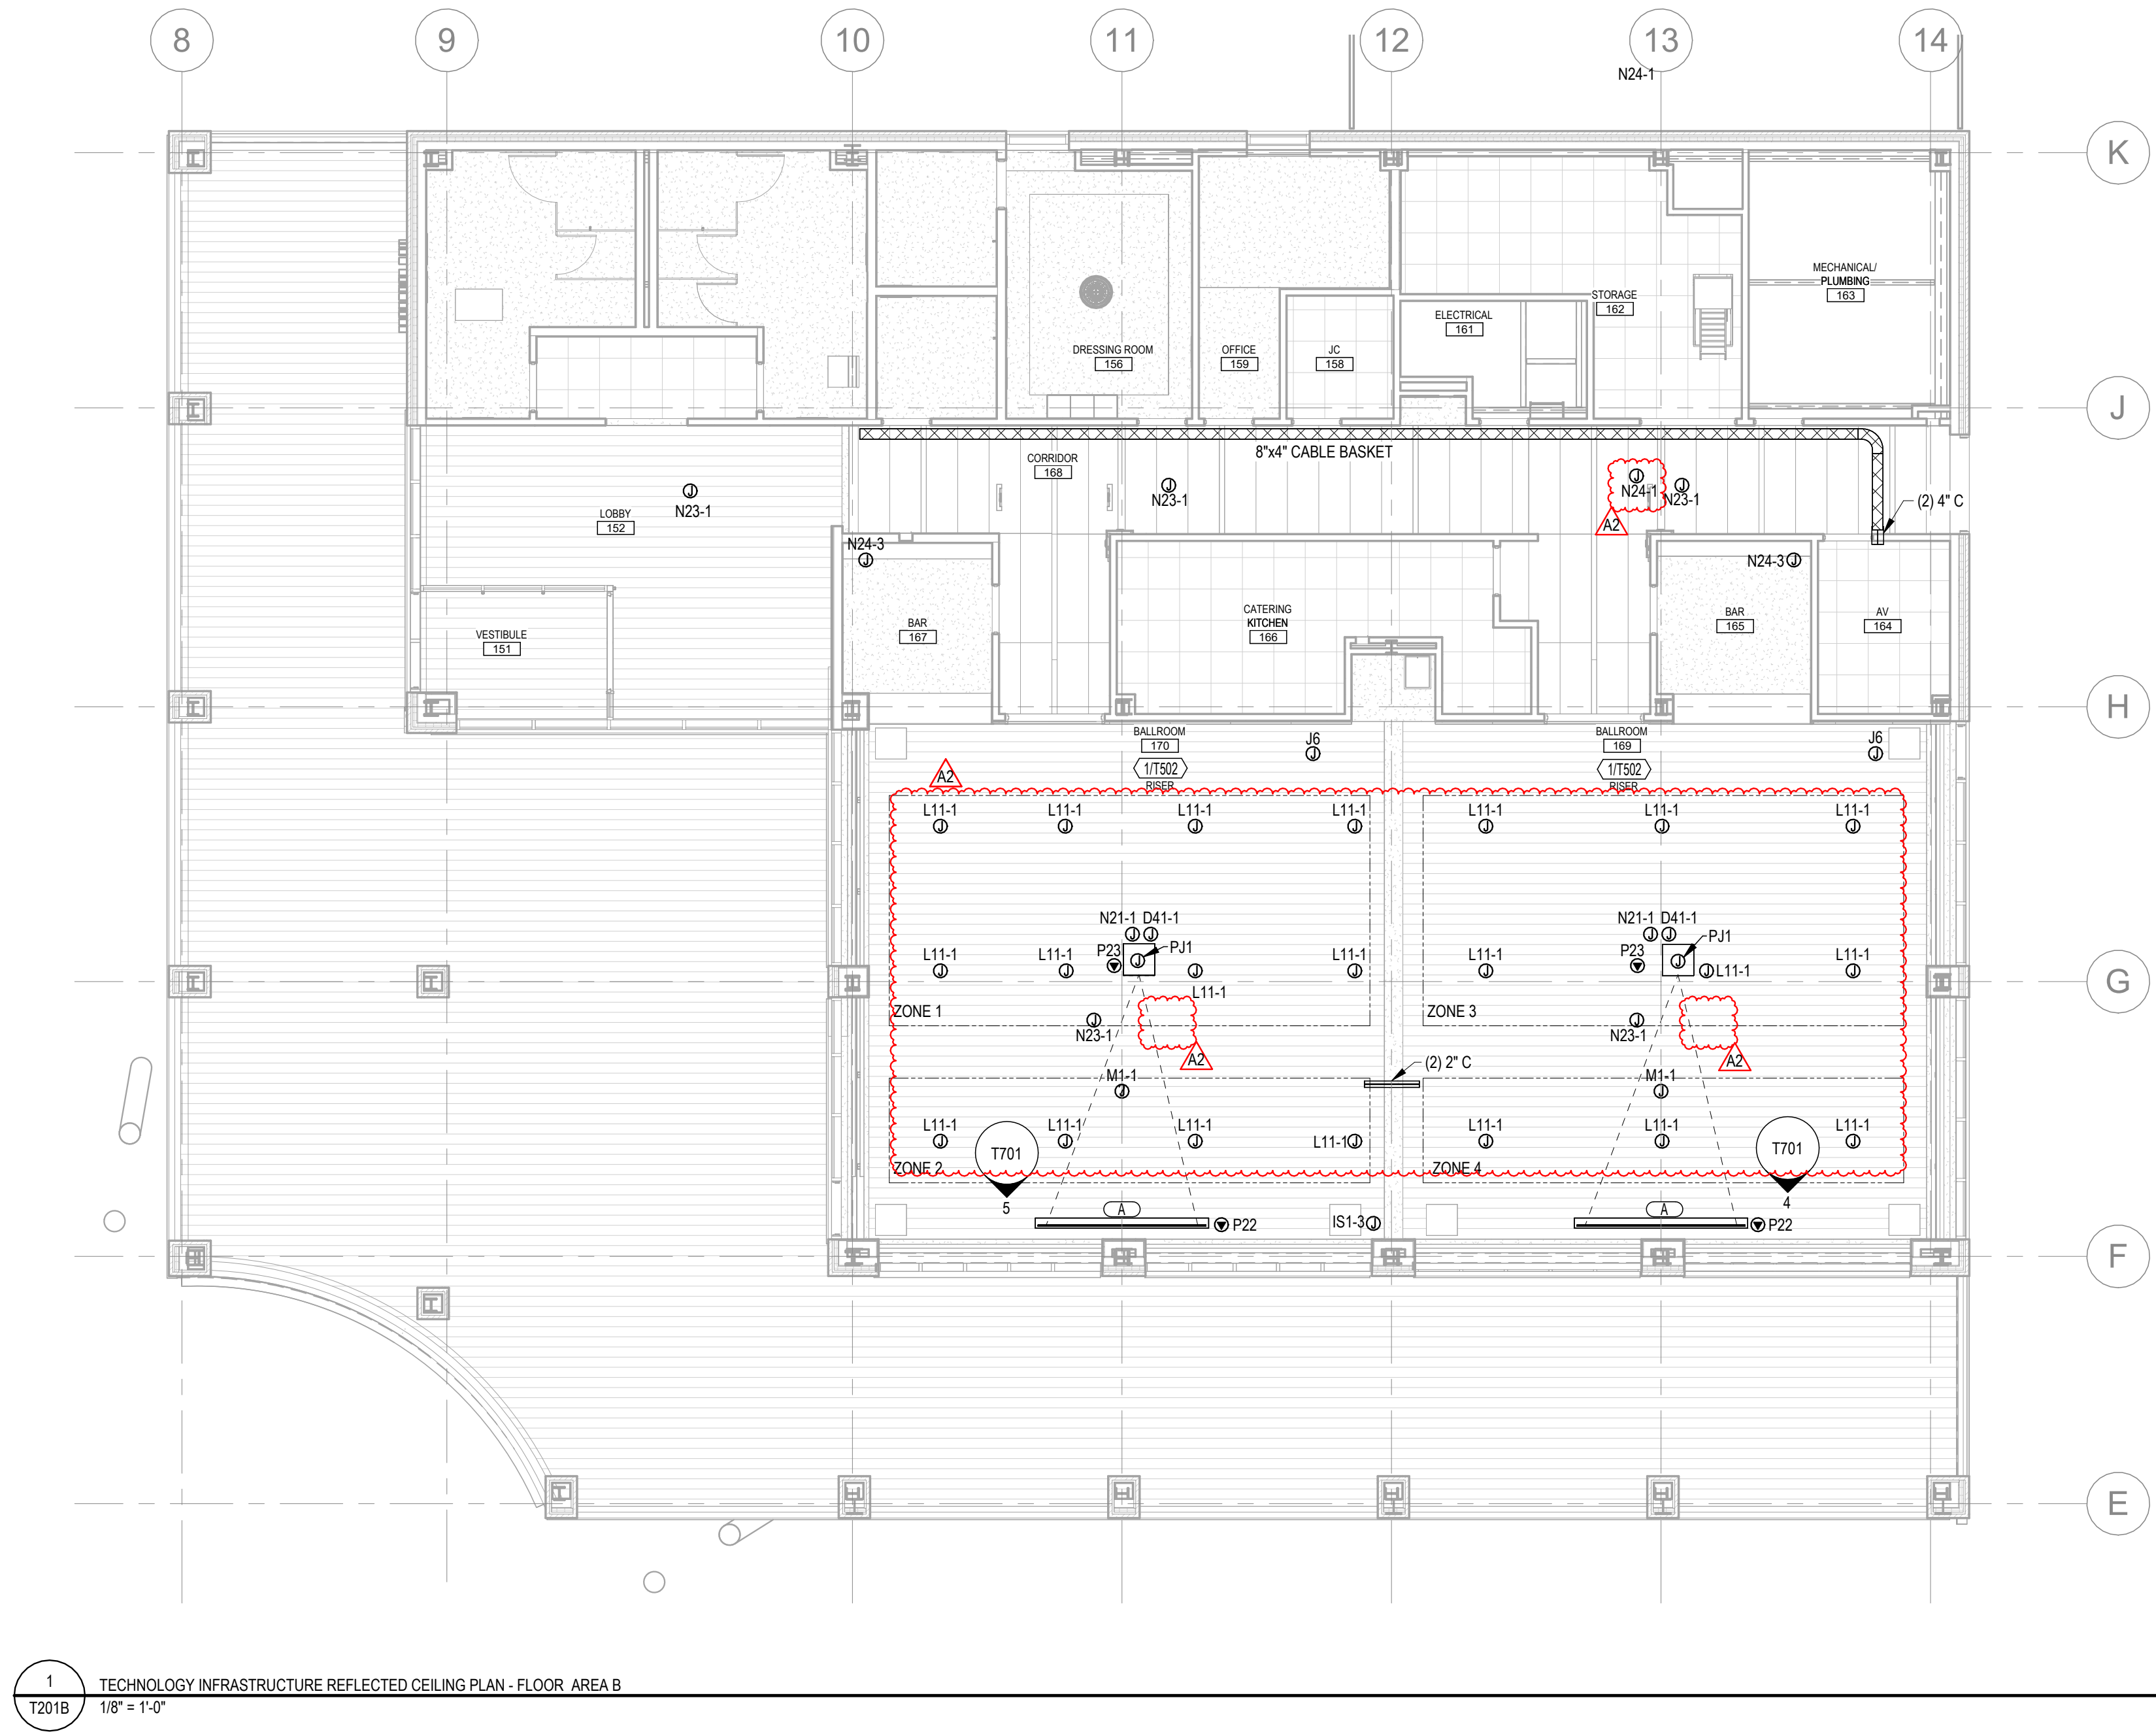

SHEET NOTES - INFRA RCP

- 1 REFER TO SHEET T001 FOR ALL TECHNOLOGY INFRASTRUCTURE GENERAL NOTES, LEGENDS, ABBREVIATIONS, AND SHEET INDEX.
- 2 REFER TO SHEET T002 & T003 FOR ALL INFRASTRUCTURE SCHEDULES AND LEGENDS

KEY PLAN

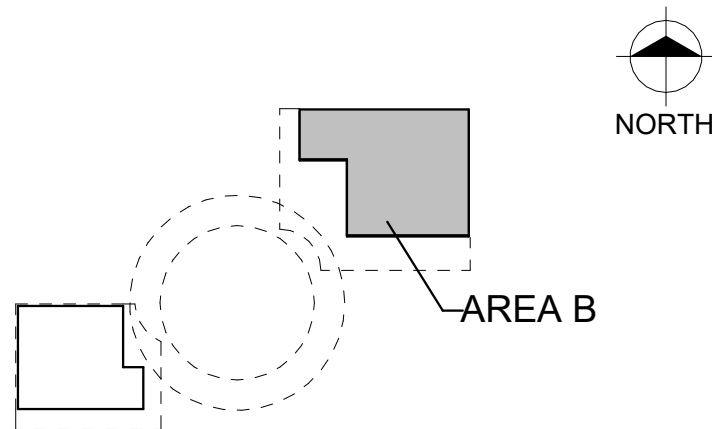

Van Buren Charter Township

Van Buren Township, MI

The Lakeside Park

REVISIONS

10/27/2026	A2	ADDENDUM 02
------------	----	-------------

10/12/2026 BID AND PERMIT SET

Drawn By TGAUNTNER
Designer JFISHMAN,
TROBINETTE
Reviewer DCHITTY
KKESTETTER
Manager CKRETOVIC

Hard copy is intended to be 24"x36" when plotted. Scale(s) indicated and graphic quality may not be accurate for any other size.


PROJECT NO.
2500281

SHEET NO.

T201B


©Copyright 2026
All Rights Reserved

PLOT INFO: 10/26/2026 12:59:16 PM Autodesk Docs://2500281 - Van Buren Twp Lake House2026_T_2500281.rvt

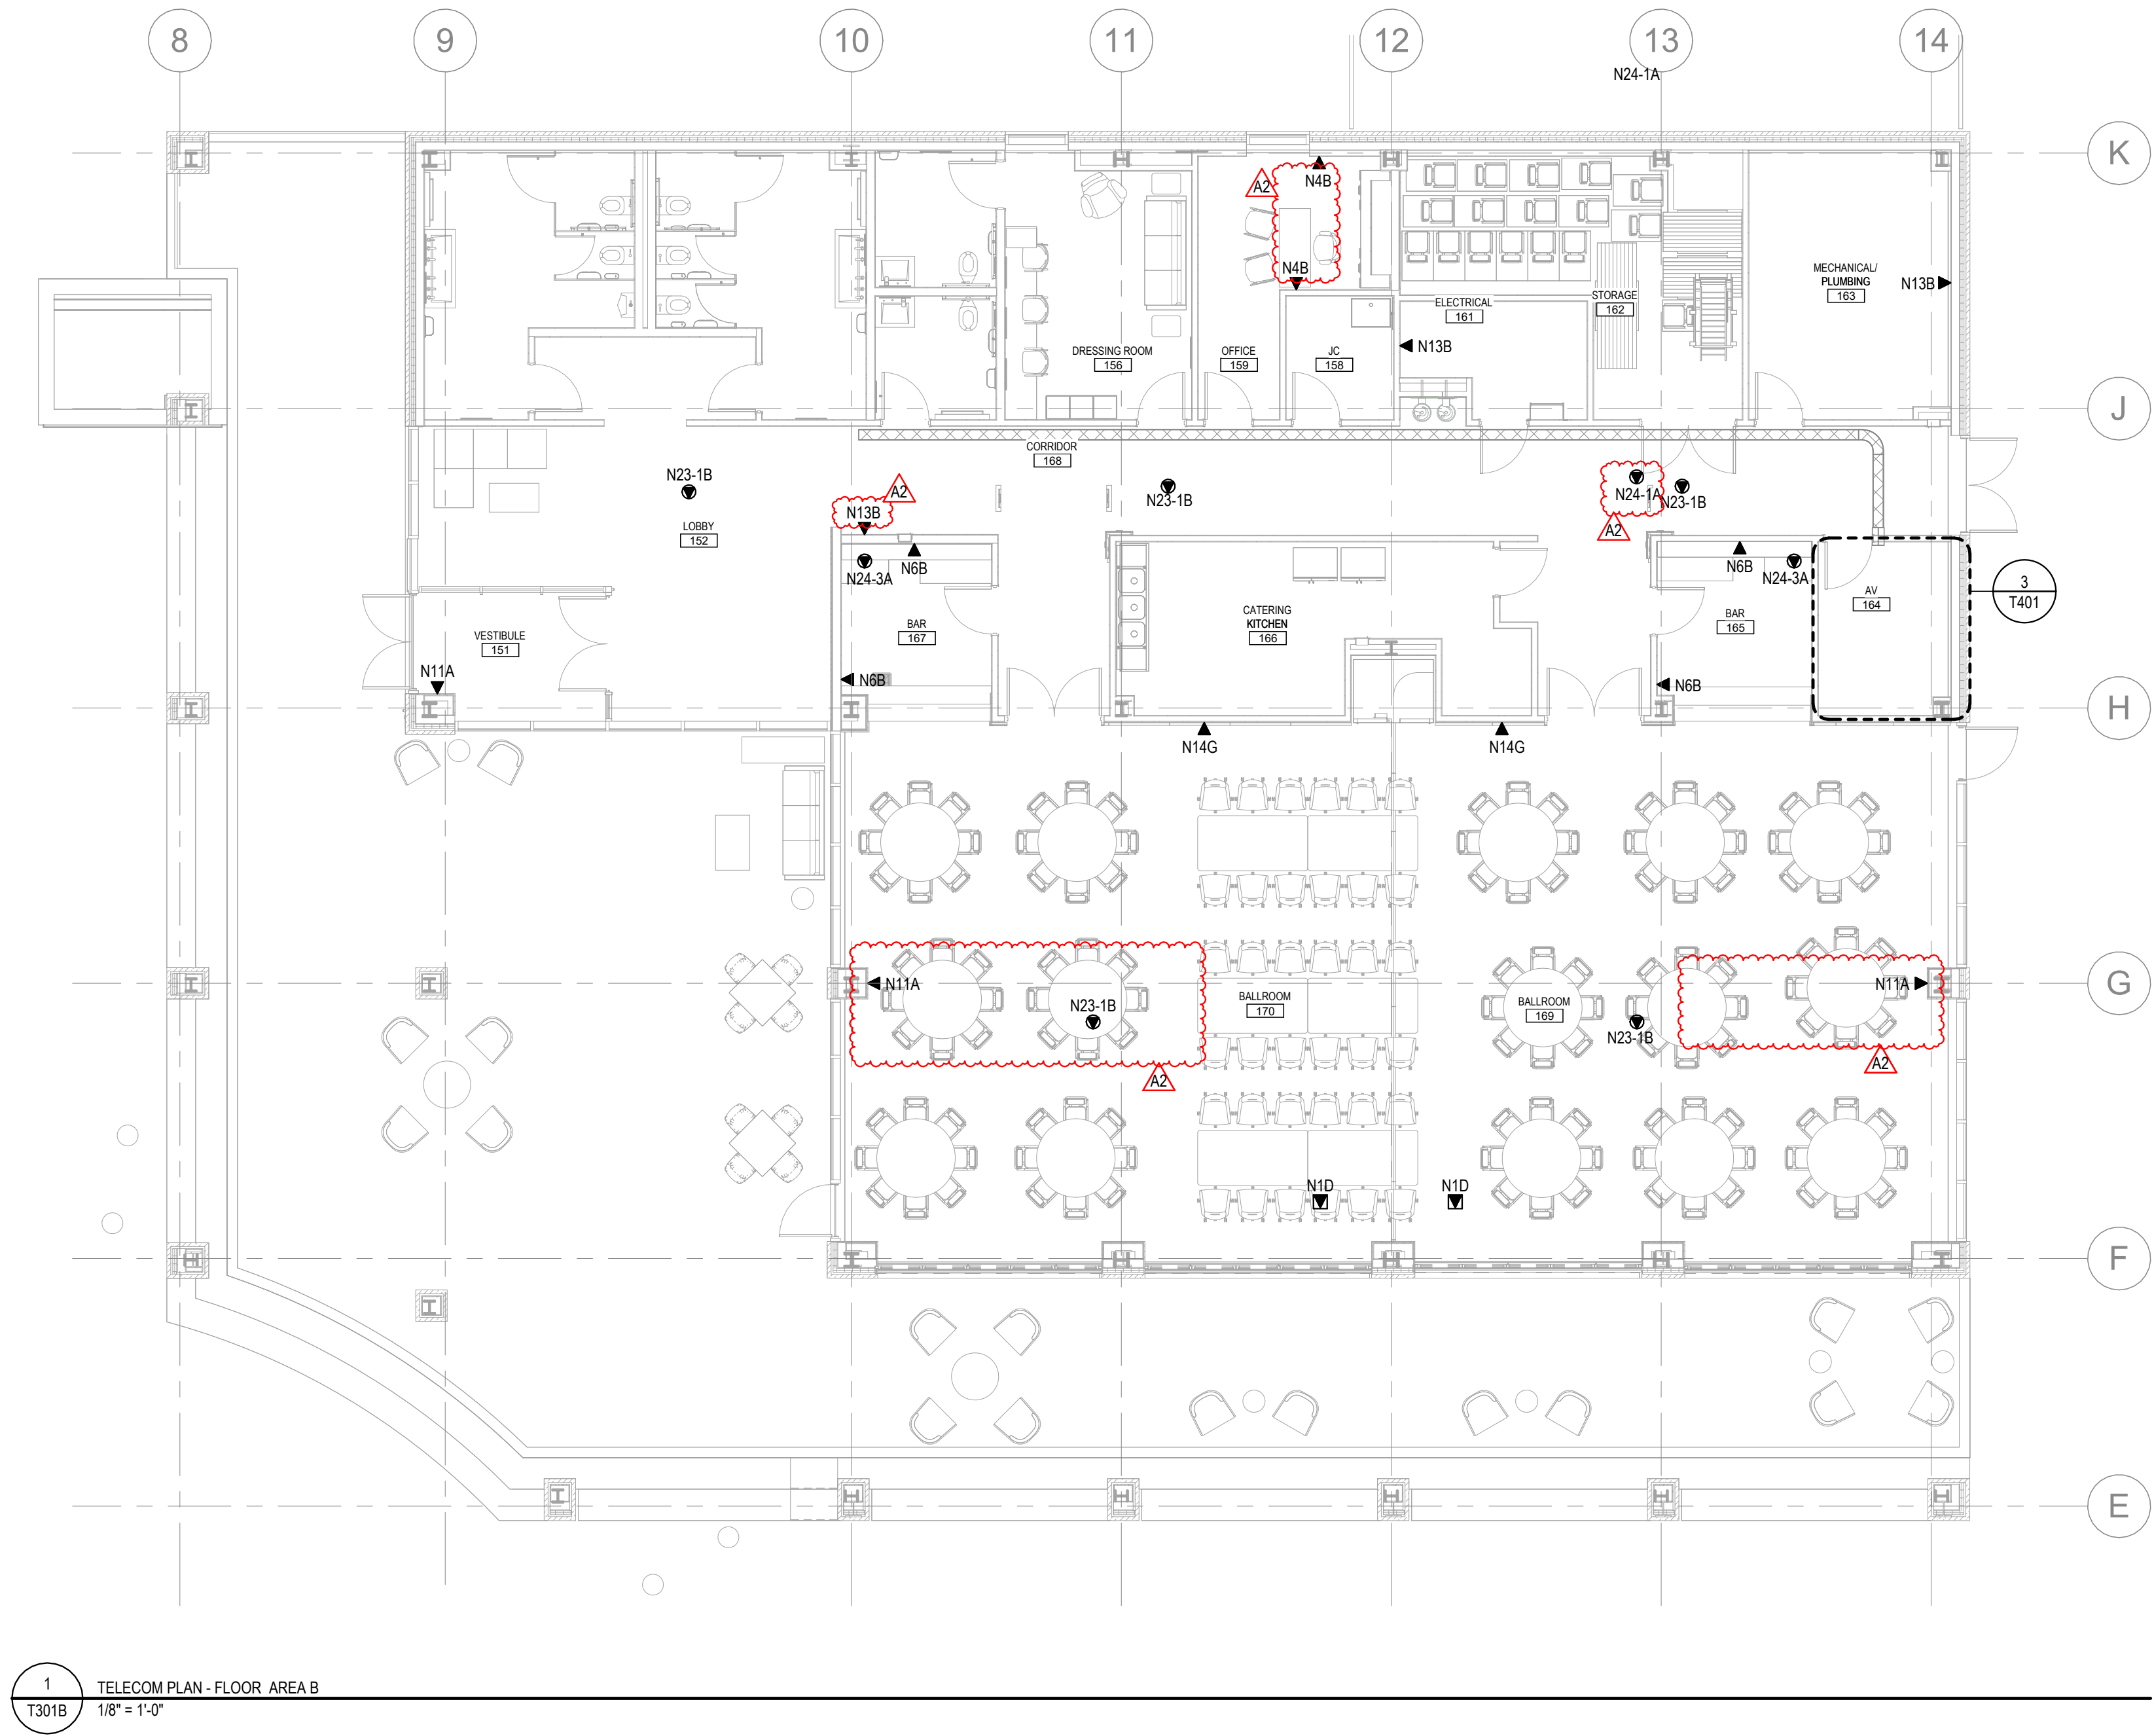

SHEET NOTES - TELECOM					
1	REFER TO SHEET T001 FOR ALL TELECOM GENERAL NOTES, LEGENDS, ABBREVIATIONS, AND SHEET INDEX.				
2	REFER TO SHEET T002 & T003 FOR ALL TELECOM SCHEDULES AND LEGENDS				
TELECOM CABLING LEGEND					
TYPE	CAT6A	FIBER	2-16AWG	REFERENCE DETAIL	NOTES
A	1	0	0	1/T901	-
B	2	0	0	1/T901	-
C	3	0	0	1/T901	-
D	4	0	0	1/T901	-
E	6	0	0	1/T901	-
F	0	4	2	-	HARD WIRED TO FIBER TRANSCEIVER & POWER
G	1	0	0	1/T901	DIRECT CONNECT

KEY PLAN

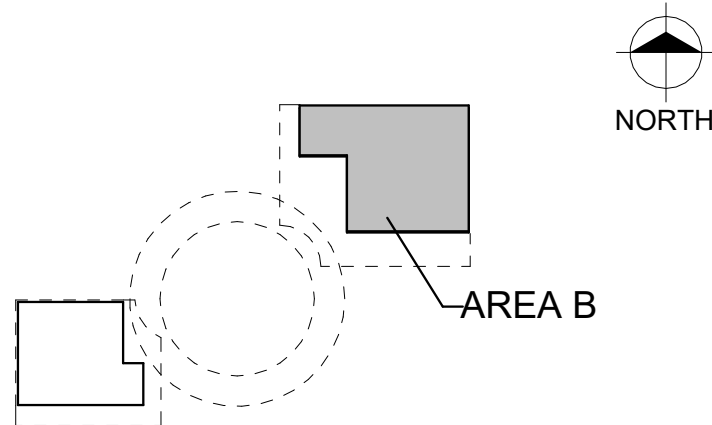

Van Buren Charter Township
Van Buren Township, MI
The Lakeside Park

REVISIONS		
10/27/2026	A2	ADDENDUM 02

10/12/2026	BID AND PERMIT SET
Drawn By	TGAUNTNER
Designer	JFISHMAN, TROBINETTE
Reviewer	DCHITTY, KKERSTETTER
Manager	CKRETOVIC


Hard copy is intended to be 24"x36" when plotted. Scale(s) indicated and graphic quality may not be accurate for any other size.

PROJECT NO.
2500281
SHEET NO.


T301B

©Copyright 2026
All Rights Reserved


PLOT INFO: 10/26/2026 12:59:18 PM Autodesk Docs://2500281 - Van Buren Twp Lake House2026_T_2500281.rvt

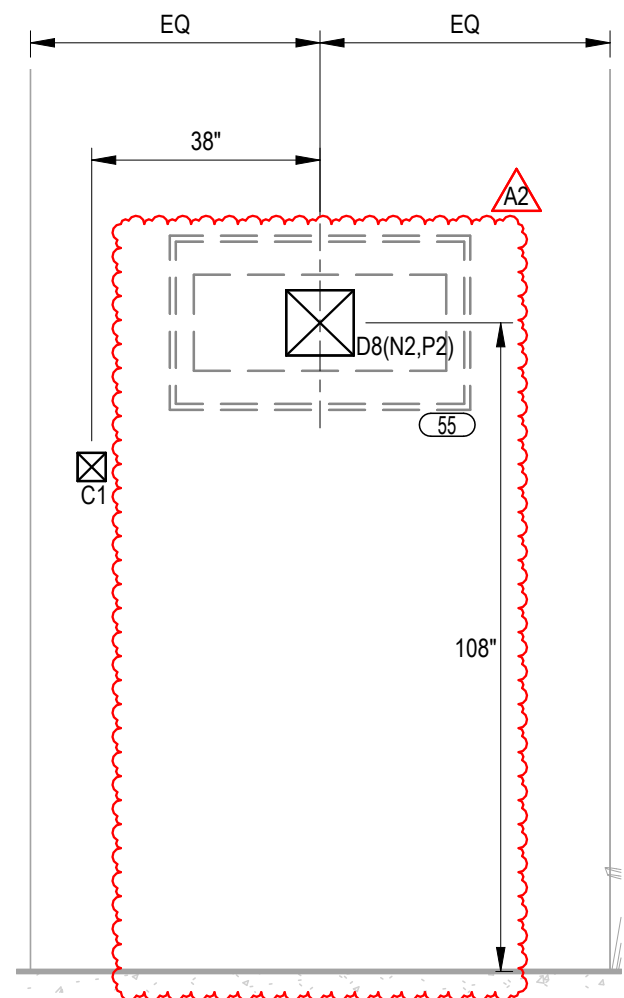


1
T701
104 - COMMUNITY LIVING ROOM
3/8" = 1'-0"

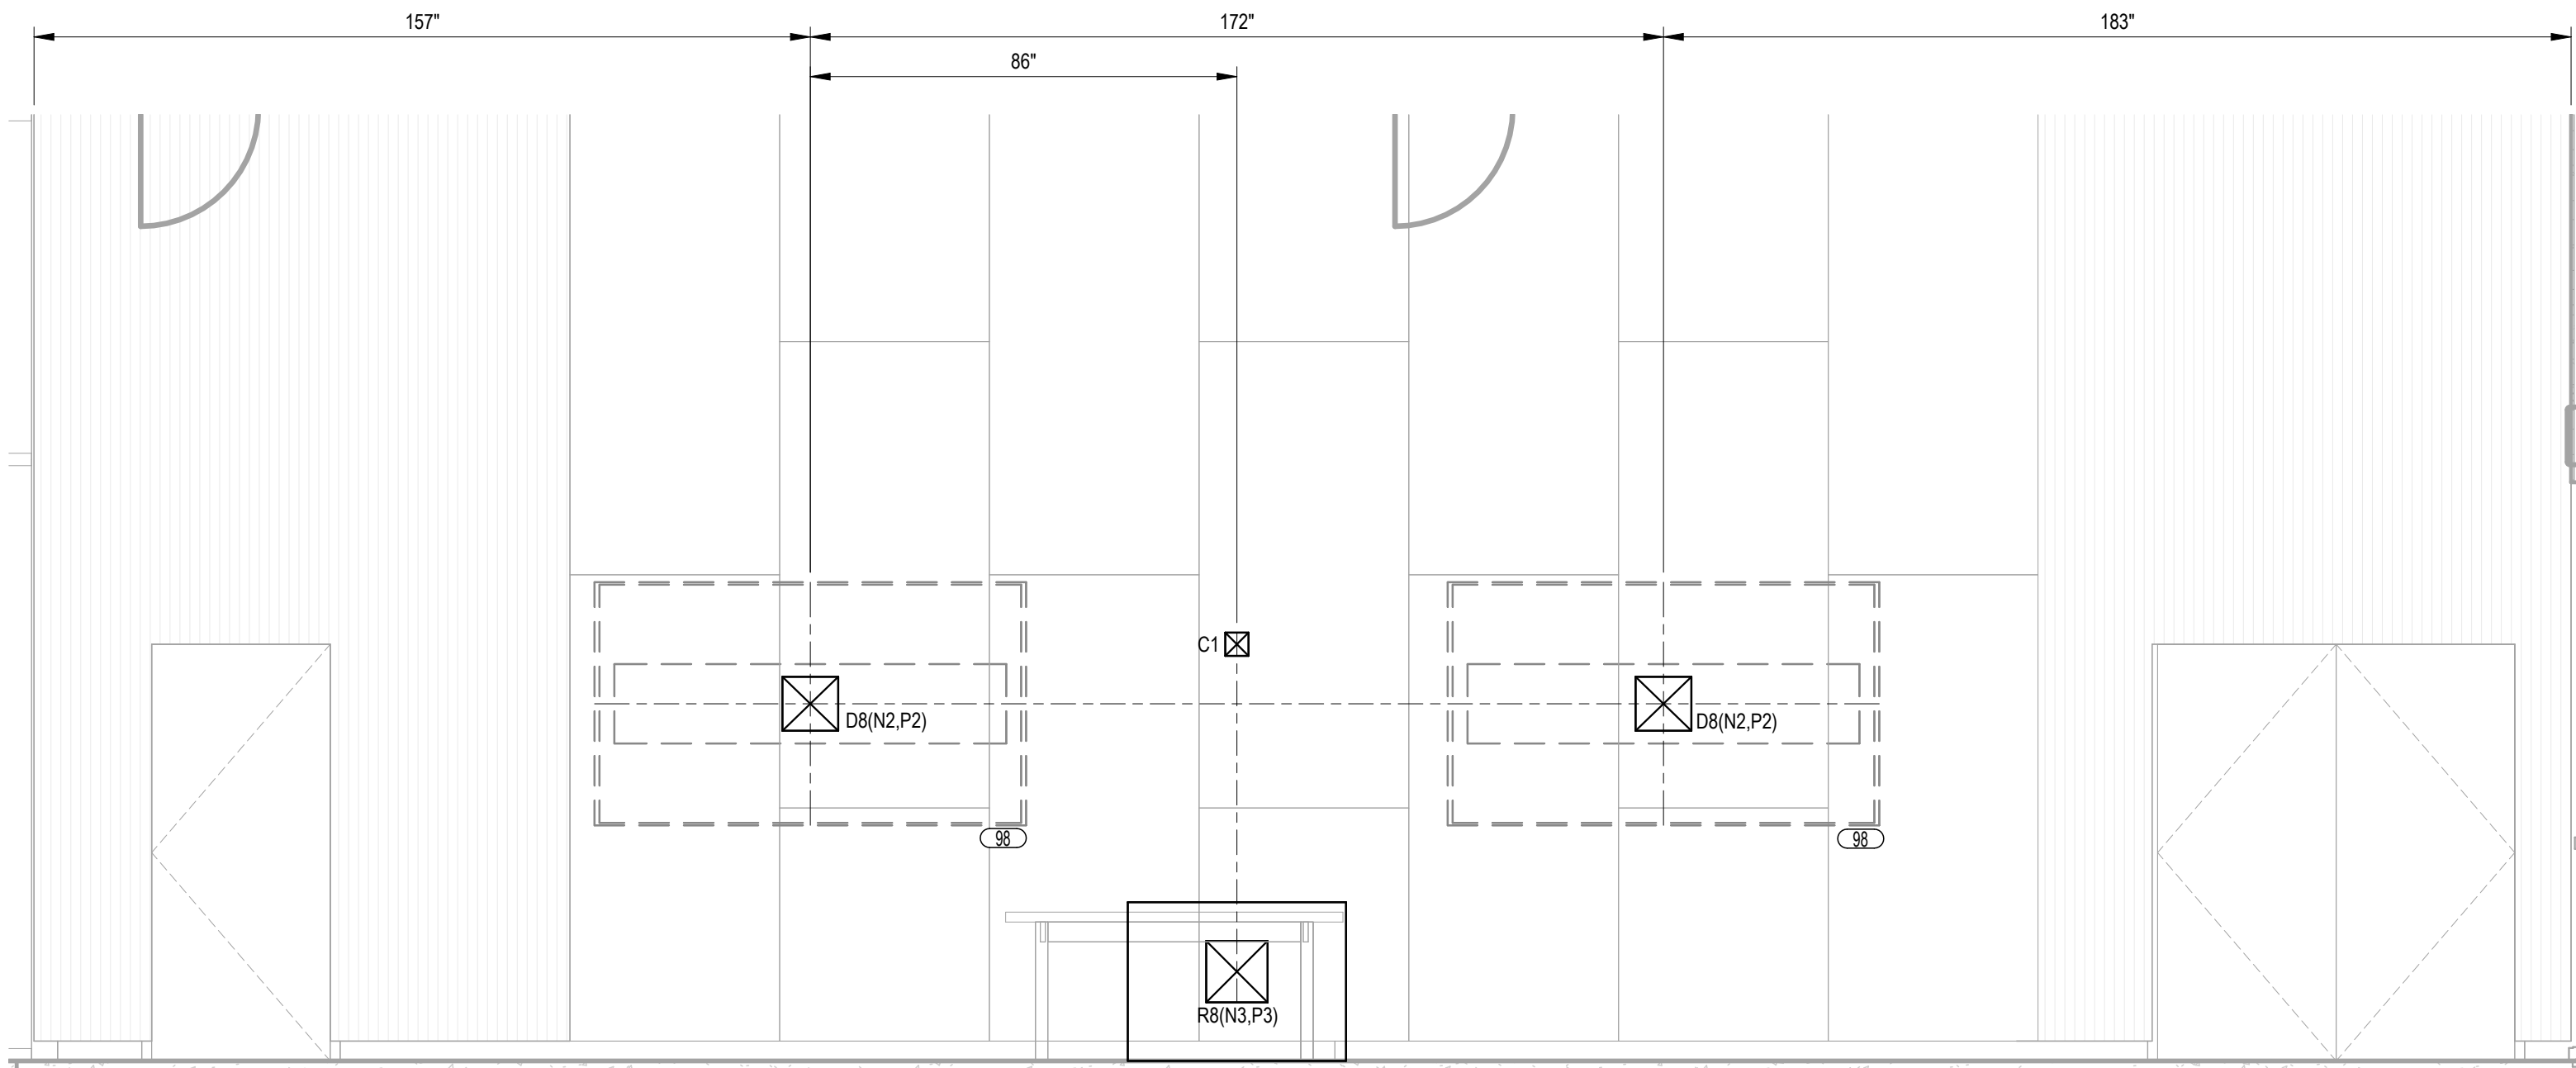


2
T701
105 - MULTI PURPOSE ROOM
3/8" = 1'-0"

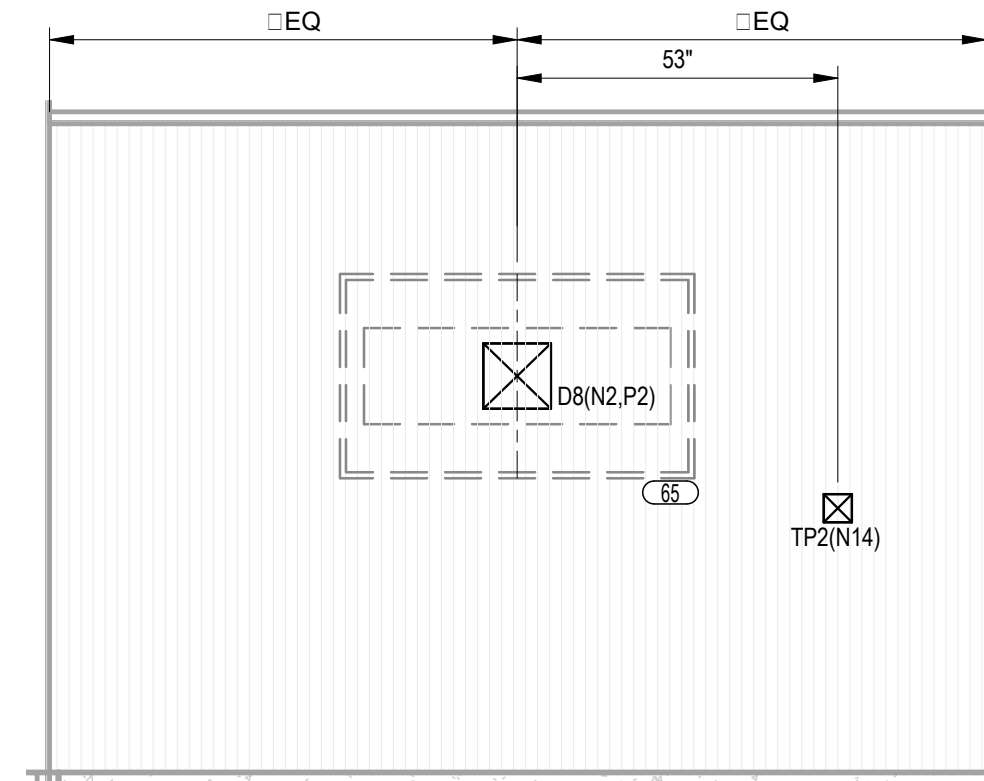

3
T701
118 - MEETING
3/8" = 1'-0"

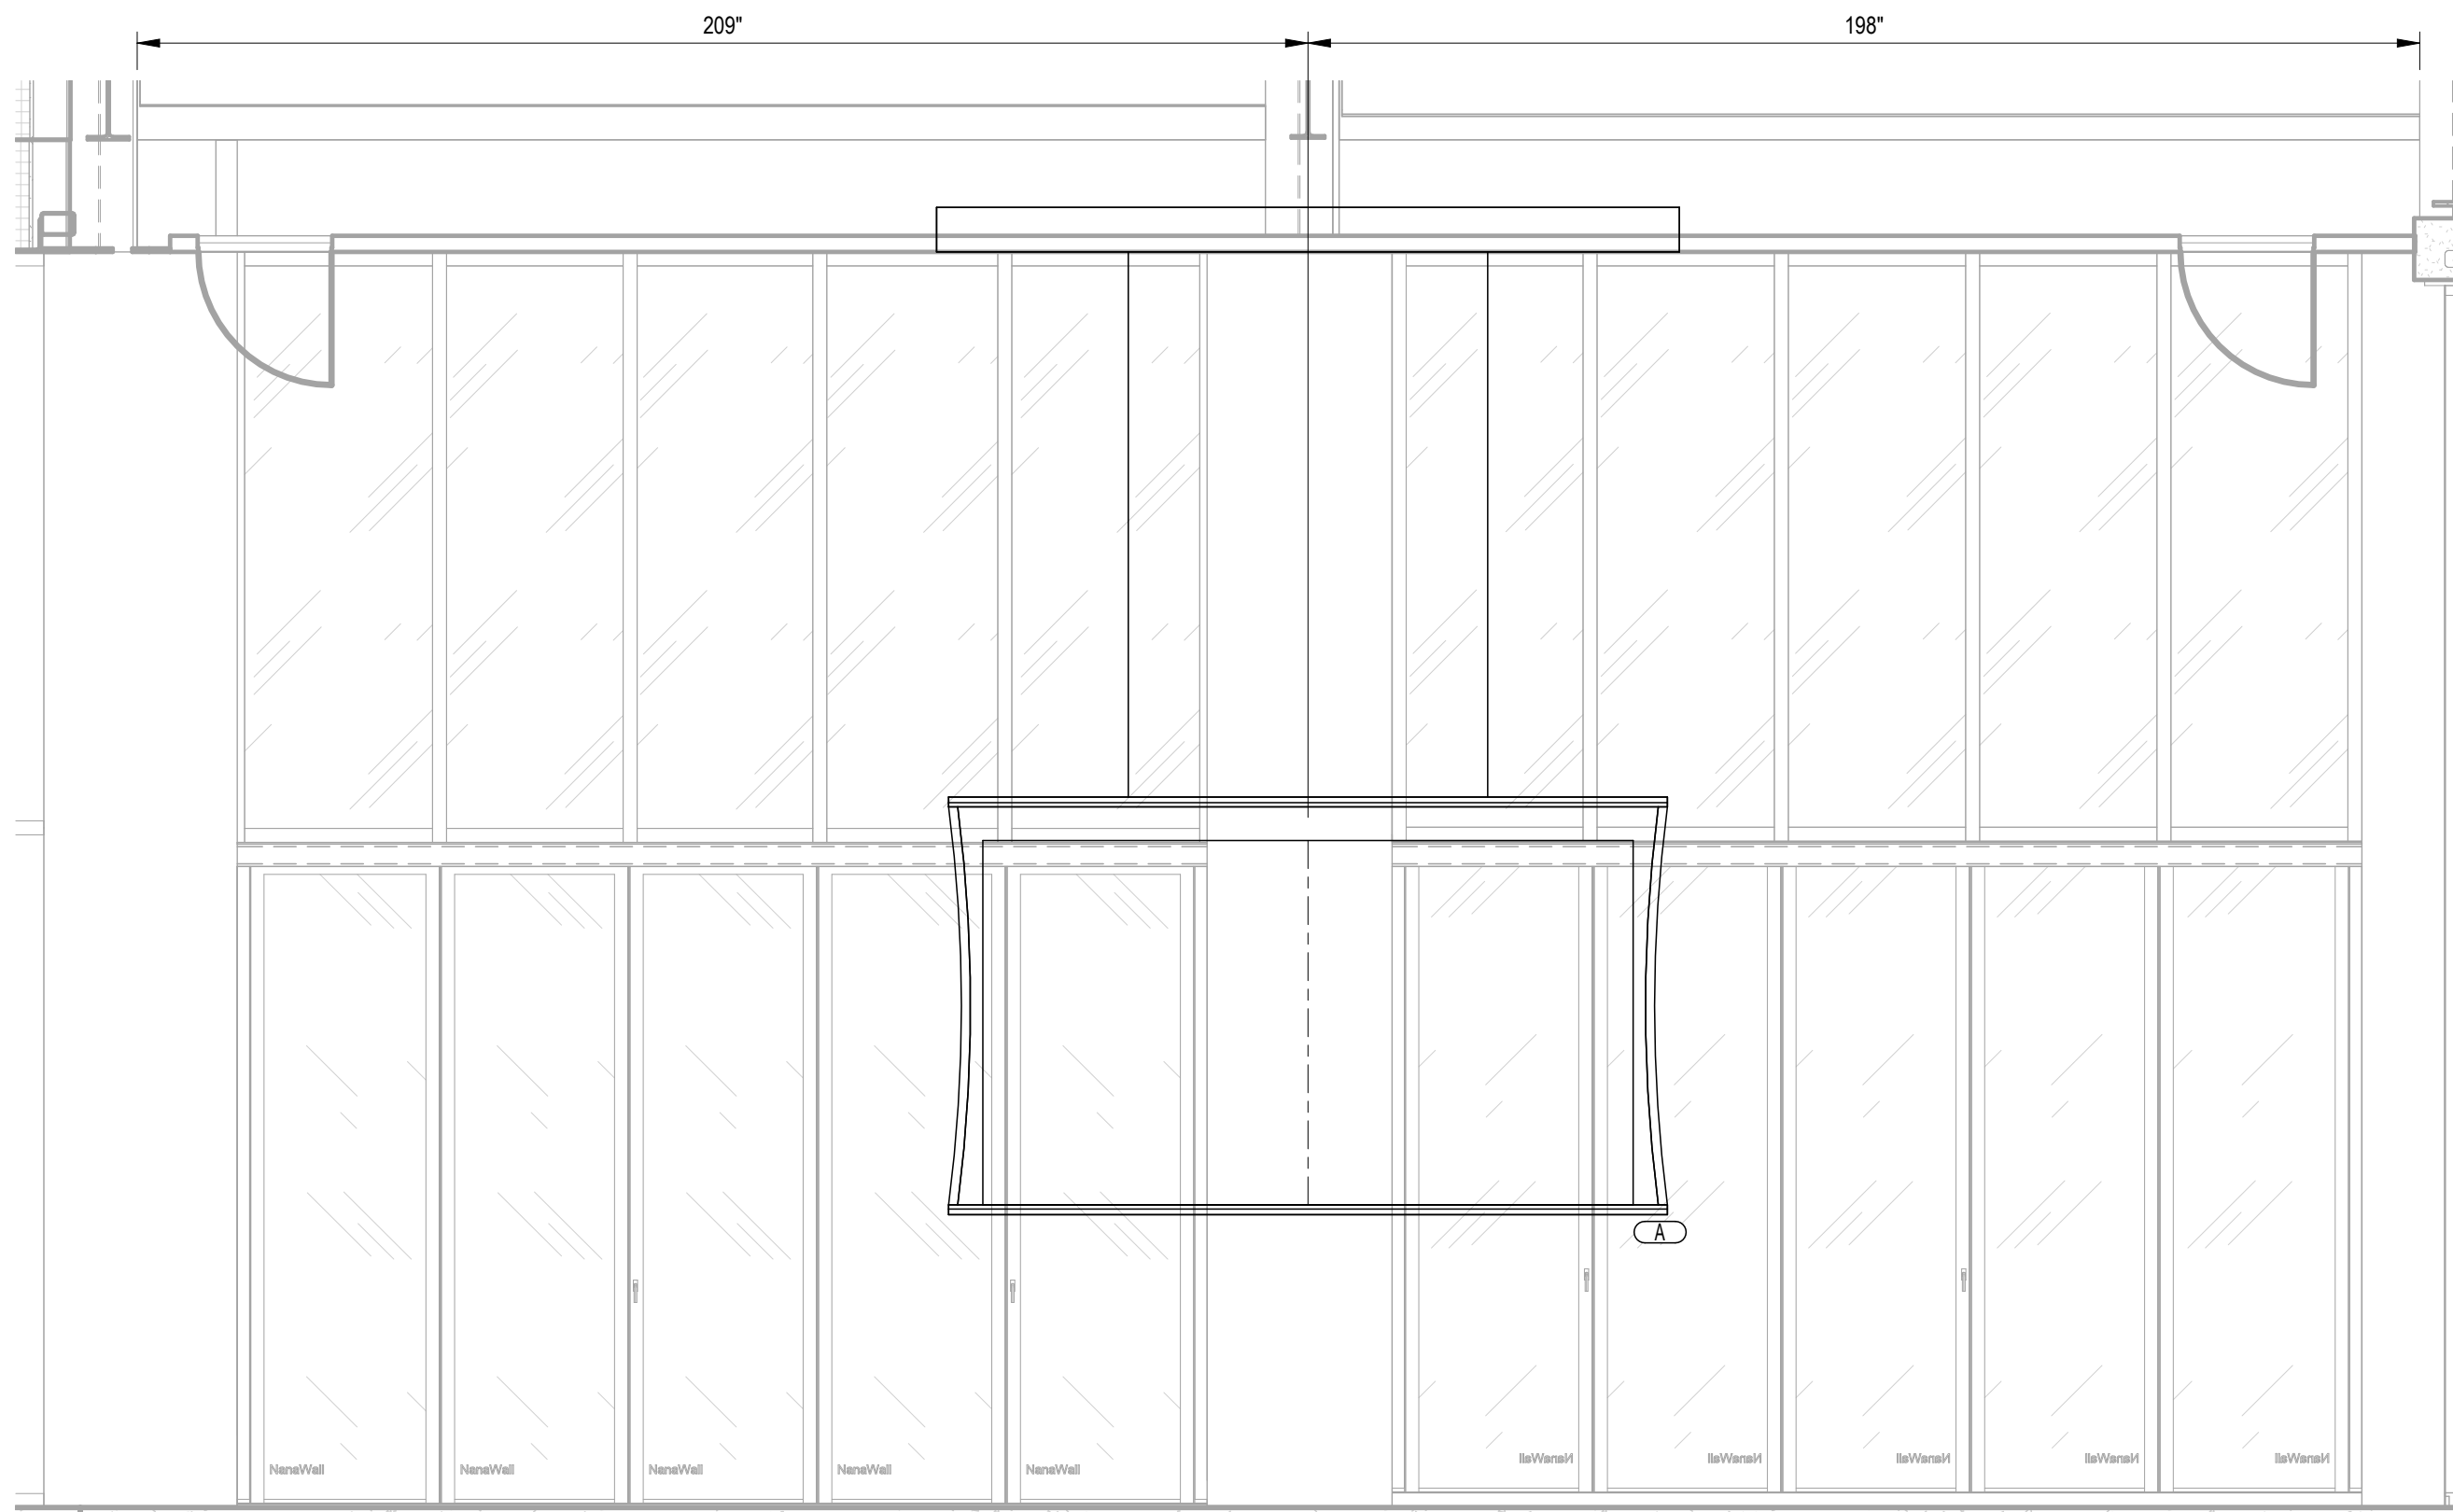

4
T701
169 - BALLROOM
3/8" = 1'-0"

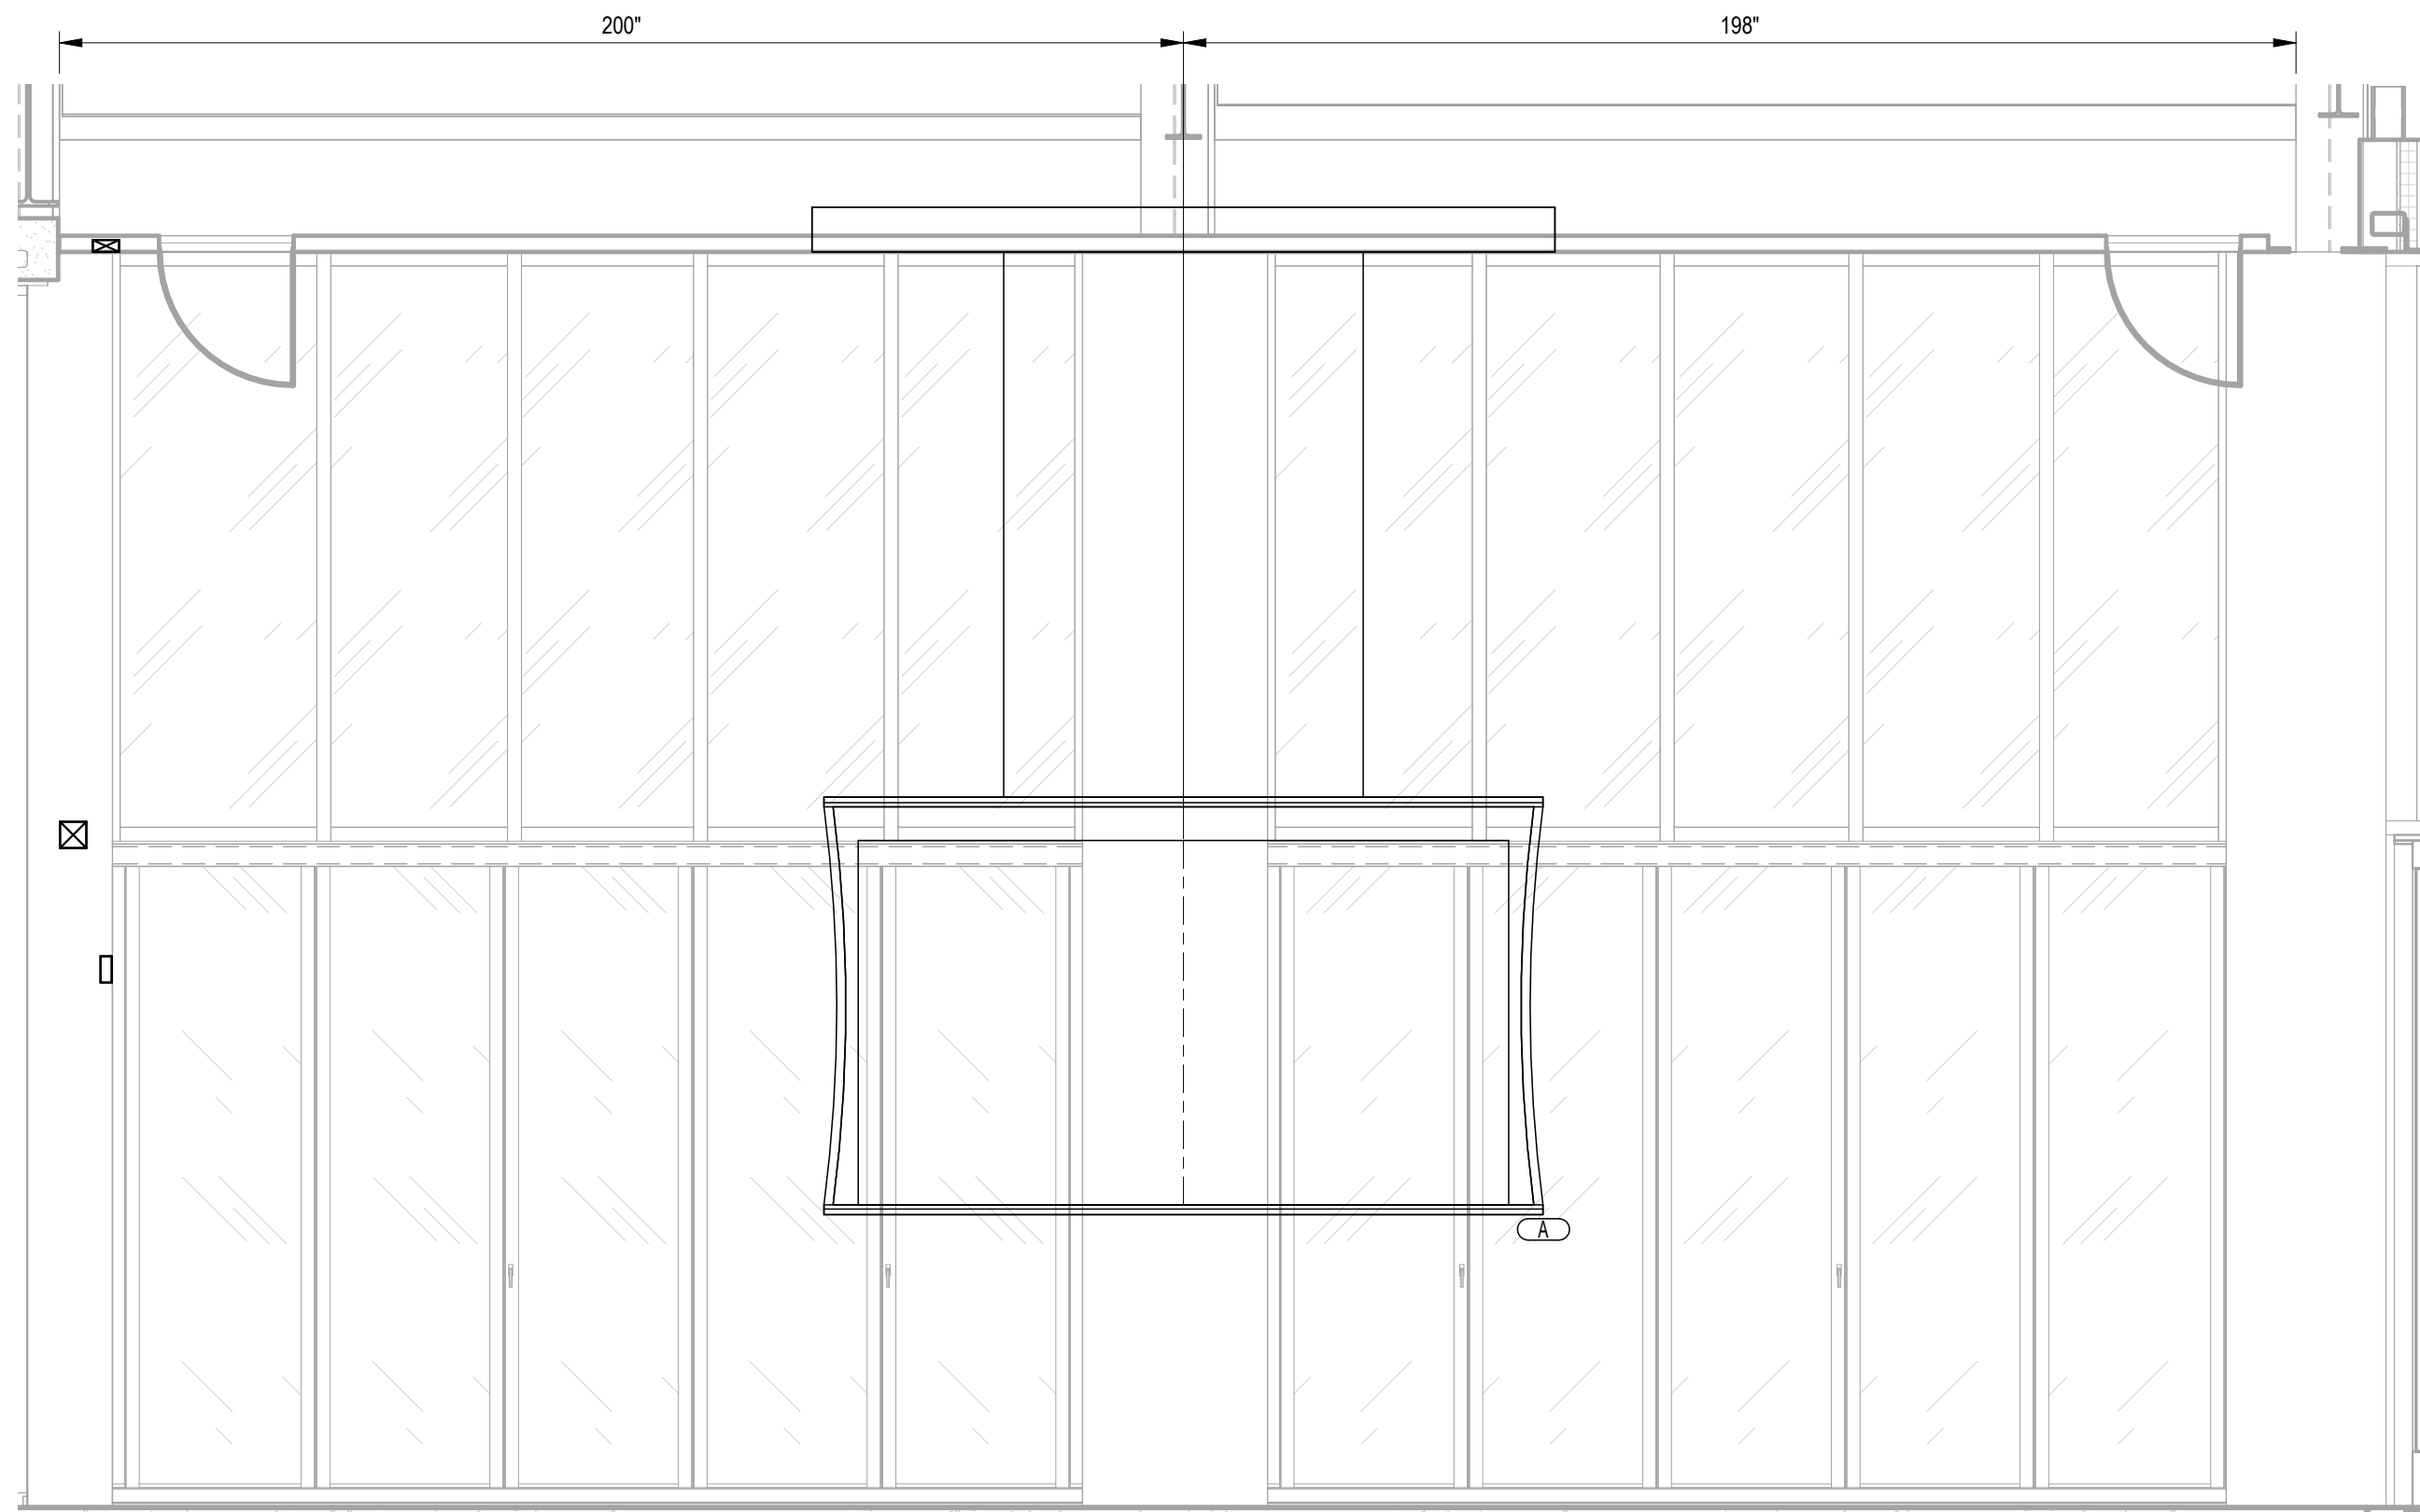

5
T701
170 - BALLROOM
3/8" = 1'-0"

REVISIONS		
10/27/2026	A2	ADDENDUM 02

Drawn By	TGAUNTNER
Designer	JFISHMAN, TROBINETTE
Reviewer	DCHITTY, KKERSTETTER
Manager	CKRETOVIC

Hard copy is intended to be 24"x36" when plotted. Scale(s) indicated and graphic quality may not be accurate for any other size.

PROJECT NO.
2500281

SHEET NO.

T701

SECURITY SYMBOLS LEGEND				(THIS IS A MASTER LEGEND, NOT ALL SYMBOLS MAY APPEAR ON DRAWINGS.)	
GENERAL		SECURITY DOORS		DEVICE TYPES	
SYMBOL	DESCRIPTION	SYMBOL	DESCRIPTION	ACP	ACCESS CONTROL PANEL
	KEYNOTE		ACCESS CONTROL TYPE	ADA	WITH ADA OPENERS
	REVISION NUMBER		ASSOCIATED DEVICE LOCATION	BP	BADGE PRINTER
	NEW WORK	SECURITY DOOR DESIGNATORS		CB	CODE BLUE PHONE
(E)	EXISTING WORK TO REMAIN			CR	DOOR RELEASE BUTTON
(D)	EXISTING WORK TO BE REMOVED (DEMO)			DVR	DIGITAL VIDEO RECORDER
(R)	EXISTING WORK TO BE RELOCATED			FA	FIRE ALARM TIE IN
(N)	NEW LOCATION OF EXISTING WORK			G	GATE
(M)	EXISTING EQUIPMENT TO BE REWORKED/MODIFIED	ACCESS CONTROL TYPES		GB	GLASS BREAK SENSOR
	CONNECTION TO EXISTING	CR	CARD READER	IC	INTERCOM
	DISCONNECTION FROM EXISTING	CRK	CARD READER W/ KEYPAD	ICM	INTERCOM MASTER
		DC	DOOR CONTACT	ICP	INTRUSION DETECTION CONTROL PANEL
		EC	ELECTRONIC CONTROL	IL	INTER-LOCK
		FOR	FUTURE CARD READER	K	KNOX BOX
		ML	MANUAL LOCK	KP	KEYPAD
		SECURITY CAMERAS		LA	LOCAL ALARM SOUNDER
		SECURITY CAMERAS		MON	MONITOR
		SYMBOL	DESCRIPTION	MS	MOTION SENSOR
			FIXED CAMERA	NVR	NETWORK VIDEO RECORDER
			PTZ CAMERA	OH	OVERHEAD DOOR CONTACT
			90° DUO CAMERA	PB	PANIC BUTTON
			180° DUO CAMERA	PS	POWER SUPPLY
			270° CAMERA	REX	REQUEST TO EXIT MOTION DETECTOR
			360° CAMERA	REX-B	REQUEST TO EXIT RELEASE BUTTON
				SC	SECURITY CONTRACTOR
				SCC	STRUCTURED CABLE CONTRACTOR
				T	TICKET
				TS1	TURNSTILE - ADA
				TS2	TURNSTILE
				UPS	UNINTERRUPTIBLE POWER SUPPLY
				VI	VIDEO INTERCOM
				VIM	VIDEO INTERCOM MASTER
				W	WIRELESS
				WS	SECURITY WORKSTATION
SECURITY DEVICES		SECURITY CAMERA DESIGNATORS		ADDITIONAL INFORMATION	
SYMBOL	DESCRIPTION			ADA	WITH ADA OPENERS
	WALL MOUNTED DEVICE			FA	FIRE ALARM TIE IN
	CEILING MOUNTED DEVICE			G	GATE MOUNTED
SECURITY DEVICE DESIGNATORS				W	WIRELESS
D-####	DEVICE NUMBER - REFER TO THE SECURITY DEVICE SCHEDULE FOR MORE INFORMATION.				
	DEVICE TYPE				
X	ADDITIONAL INFORMATION				

SECURITY GENERAL NOTES

GENERAL NOTES

1. THESE DRAWINGS MUST BE USED IN CONJUNCTION WITH THE FOLLOWING SPECIFICATIONS: DIV-28 SECURITY, DIV-08 HARDWARE, DIV-26 ELECTRICAL, DIV-27 COMMUNICATIONS.
2. FURNISH AND INSTALL FIRE STOP TO ALL SLAB AND WALL PENETRATIONS PROVIDED FOR THE INSTALLATION OF SECURITY CABLE AS REQUIRED TO MAINTAIN FIRE RATING OF SLAB OR WALL.
3. NOTIFY THE ENGINEER OF ANY DISCREPANCIES BETWEEN THESE CONTRACT DRAWINGS AND FIELD CONDITIONS.
4. INSTALL ALL COMPONENTS AS PER MANUFACTURERS RECOMMENDATIONS AND PER ALL APPLICABLE CODES.
5. INDICATE ALL MOUNTING REQUIREMENTS IN THE LEGEND UNLESS OTHERWISE NOTED.
6. VERIFY AND COORDINATE THE EXACT MOUNTING LOCATION OF ALL DEVICES PRIOR TO INSTALLATION.
7. THE MOUNTING HEIGHTS ARE TO THE CENTERLINE OF THE DEVICE UNLESS OTHERWISE NOTED.
8. RESTORE CEILINGS AND WALLS AND ANY OTHER SURFACES AFFECTED BY THIS WORK WITH LIKE MATERIALS TO MATCH EXISTING CONSTRUCTION UPON COMPLETION OF THE SECURITY WORK.

ELECTRICAL DRAWINGS AND COORDINATION:

1. COORDINATE WALL BOX LOCATIONS AND DIMENSIONS WITH ARCHITECTURAL AND ELECTRICAL DRAWINGS.
2. COORDINATE WITH ELECTRICAL DRAWINGS FOR LOCATION OF ALL SECURITY EQUIPMENT.
3. ALL CONDUIT, PATHTAYS, AND STANDARD BACK BOXES FOR SECURITY EQUIPMENT ARE TO BE PROVIDED BY THE ELECTRICAL CONTRACTOR.
4. POWER CIRCUITS FOR SECURITY EQUIPMENT ARE TO BE PROVIDED BY THE ELECTRICAL CONTRACTOR.
5. SECURITY CONTRACTOR SHALL COORDINATE ALL SECURITY WORK AND REQUIREMENTS WITH ELECTRICAL CONTRACTOR PRIOR TO ROUGH-IN WORK.

CONDUIT:

1. COORDINATE CONDUIT AND LADDER RACK FOR SECURITY WIRING TO MAINTAIN A MINIMUM OF 1" SEPARATION FROM LIGHTING FIXTURES.
2. COORDINATE INSTALLATION OF CONDUITS AND CABLE BASKETS WITH OTHER COMPONENTS INSTALLED WITHIN THE CEILING. PREPARE ALL SHOP DRAWINGS TO DEMONSTRATE AND ENSURE PROPER INSTALLATION OF ALL COMPONENTS.
3. MAINTAIN MINIMUM BEND RADIUS OF 10 X O.D. FOR SECURITY CONDUITS EQUAL TO OR LESS THAN 2" DIAMETER.
4. REAM AND BUSH THE ENDS OF ALL CONDUITS.
5. PROVIDE AND LEAVE IN PLACE A PULL STRING IN EACH CONDUIT. PULL STRINGS SHALL ALSO BE INSTALLED IN ALL SPARE/EMPTY CONDUITS.
6. STUB UP CONDUIT SLEEVES THROUGH SLABS 6" ABOVE FINISHED FLOORS.
7. PROVIDE HANGERS, ANCHORS, MOUNTING HARDWARE, GROUND LUGS, AND STRAPS AS REQUIRED TO ENSURE PROPER INSTALLATION OF PATHWAY COMPONENTS.
8. PROVIDE ALL LADDER RACK AND CABLE BASKET LOCATIONS: RUNWAY, DROP-OFFS, SPICE HARDWARE, GROUND STRAPS, THERMAL EXPANSION PLATES, TERMINATION KITS, END SUPPORT KITS, AND CEILING SUPPORT HARDWARE.
9. WHERE CABLE IS RUN ABOVE NON-ACCESSIBLE (I.E. GYPSUM BOARD) CEILING CONSTRUCTION, CONDUITS, AND PULL BOXES MUST BE INSTALLED TO PROPERLY ROUTE CABLE.
10. PROVIDE J-HOOKS AND CABLE STRAPS TO SUPPORT CABLE ABOVE ACCESSIBLE CEILING CONSTRUCTION EXCEPT IN AREAS WHERE CABLE BASKET OR CONDUIT IS INDICATED ON THE DRAWINGS.
11. ALL CONDUIT SHALL BE A MINIMUM OF 1" EMT UNLESS OTHERWISE NOTED.
12. ALL CONDUIT SHALL BE ROUTED ABOVE CEILING, BELOW FLOORS, OR WITHIN WALLS IN THE FINISHED AREAS. NO CONDUIT SHALL BE EXPOSED IN THE FINISHED AREAS UNLESS ALLOWED BY DESIGNER.
13. ALL CONDUITS SHALL HAVE PLASTIC BUSHINGS INSTALLED AT OPEN ENDS PRIOR TO PULLING WIRE.
14. ALL BACK BOXES SHALL BE FLUSH MOUNTED UNLESS OTHERWISE NOTED.
15. ALL BACK BOXES MOUNTED WITHIN FIRE RATED PARTITIONS SHALL MEET THE FIRE RATING OF THE PARTITION AS REQUIRED BY CODE.
16. COORDINATE THE EXACT LOCATION OF ALL PULL BOXES WITH ARCHITECTURAL, ELECTRICAL, AND MECHANICAL DRAWINGS.
17. ALL JUNCTION AND PULL BOXES SHALL BE PROVIDED WITH ACCOMPANYING BLANK COVER PLATE.
18. JUNCTION BOXES LOCATED ABOVE DOORS WITH NO ACCESSIBLE CEILING SHALL BE SECURED WITH TAMPER PROOF SCREWS.
19. PROVIDE WATER TIGHT SEALING ASSEMBLIES WITH PRESSURE BUSHING AS REQUIRED FOR EXTERIOR PENETRATIONS.
20. JUNCTION AND PULL BOXES IN EXTERIOR LOCATIONS SHALL BE WATERPROOF.
21. JUNCTION AND PULL BOXES IN INTERIOR AREAS SHALL BE RATED TO MEET FIRE PROTECTION DRAWINGS) SHALL BE VAPOR TIGHT.
22. ALL CONDUIT ROUTING SHOWN IS SCHEMATIC AND DOES NOT REPRESENT INSTALLED PATHS OR DISTANCES. ACTUAL ROUTING AND BOX LOCATIONS SHALL BE FIELD VERIFIED AND COORDINATED WITH OTHER WORK OF THE CONTRACT.

CABLE:

1. FURNISH AND INSTALL SECURITY CABLING FROM DEVICE TO TERMINATION POINT, AS INDICATED IN DEVICE SCHEDULES. DATA CABLING SHALL BE PROVIDED AND INSTALLED BY DIV-27 STRUCTURED CABLING CONTRACTOR.
2. ALL CABLES SHALL BE PLENUM RATED WHERE REQUIRED.
3. WIRE SHEATH SHALL BE MAINTAINED TO FINAL TERMINATION. ALL TERMINATIONS SHALL MAINTAIN TWIST OF INDIVIDUAL PAIRS TO WITHIN 0.5" OR LESS OF FINAL TERMINATION.

LABELING:

1. PROVIDE IDENTIFICATION LABELS FOR ALL SECURITY CABLES AT BOTH ENDS.
2. PROVIDE DESIGNATION LABELS FOR ALL SECURITY PANELS, POWER SUPPLIES, CABINETS AND ENCLOSURES.
3. PROVIDE WHITE LABEL WITH TYPEWRITTEN LEGIBLE CHARACTERS PRINTED WITH NON-SMEAR TYPE INK. HANDWRITTEN LABELS ARE NOT PERMITTED.
4. PROVIDE LABELS FOR CABLES WITH PROTECTIVE WRAP AROUND PLASTIC TRANSPARENT COVER WHICH WILL SERVE TO PROTECT THE INK FROM WEAR AND TEAR AND SECURE THE LABEL TO THE CABLE. PROVIDE LABELS FOR CABLES WIDE ENOUGH FOR 24 CHARACTERS IN A SINGLE ROW.
4. ALL WIRES SHALL BE LABELED WITHIN 6.5" OF FINAL TERMINATION.

CAMERAS:

1. THE CONTRACTOR SHALL PROVIDE THE MEANS FOR OPTIMUM CAMERA LOCATION, LENS SELECTION AND VIEW. THE CONTRACTOR SHALL PROVIDE A VIDEO CAMERA WITH LENSES OF VARIOUS FOCAL LENGTHS FOR THE PURPOSE OF ACQUIRING FIELD OF VIDEO AND VIDEO PICTURE FROM EACH INTENDED CAMERA LOCATION. TO SHOW VARYING FIELD OF VIEWS AND QUALITY OF CAMERA PICTURE. THE CONTRACTOR SHALL OBTAIN CONCURRENCES OF THE SELECTED CAMERA PLACEMENT, LENS SELECTION FIELD OF VIEW, AND PROVIDE IMAGES TO THE ENGINEER FOR ACCEPTED FIELD OF VIEW.
2. UPON COMPLETION OF INSTALLATION, DOCUMENT THAT THE CAMERA LOCATIONS AND LENSES CHOSEN/UTILIZED ARE AS SELECTED IN THE INITIAL PROCEDURE AND SUBMIT THE FIELD OF VIEWS PROVIDED BY THE COMPLETED INSTALLATION FOR APPROVAL BY THE DESIGNER THAT THEY ARE COMPARABLE TO THOSE OBTAINED IN THE INITIAL SELECTION PROCEDURE.

ISSUE					SHEET NUMBER	SHEET DESCRIPTION
2026-10-12 BID AND PERMIT SET	2026-09-21 CD PEER REVIEW	2026-09-08 CD TEAM REVIEW	2026-08-10 CD 50% PROGRESS	2026-06-22 DD OWNER REVIEW		
•	•	•	•	•	Y001	SECURITY SYMBOLS LEGEND, NOTES AND SCHEDULES
•	•	•	•	•	Y100	SECURITY SITE PLAN
•	•	•	•	•	Y101A	SECURITY PLAN - FLOOR AREA A
•	•	•	•	•	Y101B	SECURITY PLAN - FLOOR AREA B
•	•	•	•	•	Y801	SECURITY DETAILS

CONTRACTOR RESPONSIBILITY MATRIX			
ALL ITEMS AND TASKS LISTED ARE THE RESPONSIBILITY OF THE NOTED CONTRACTOR.			
#	ITEM / TASK	FURNISH	INSTALL
1	ROUGH OR FINISHED TRIM, CASEWORK AND MILLWORK	GC	GC
2	AC POWER SYSTEMS, CONDUIT, RACEWAYS, ELECTRICAL BACK BOXES, SECURITY BACK BOXES, JUNCTION BOXES, PULL BOXES, FLOOR BOXES AND OTHER INFRASTRUCTURE	GC	GC
3	TELECOMMUNICATIONS STRUCTURED CABLING SYSTEMS, HORIZONTAL AND BACKBONE CABLING AND TERMINATION, ASSOCIATED CABINETS, RACKS, RACEWAYS AND CABLE MANAGEMENT SYSTEMS	SCC	SCC
4	TELECOMMUNICATIONS CONNECTOR INSERT PLATES FOR FLOOR BOXES AND / OR WALL BOXES	SCC	SCC
5	ELECTRONIC SECURITY SYSTEMS EQUIPMENT AND SECURITY CABLING FOR ACCESS CONTROL, INTRUSION ALARM, DURESS, VIDEO SURVEILLANCE, OTHERS AS SPECIFIED	SC	SC
6	ELECTRONIC LOCKS AND ELECTRIFIED HINGES	DH	SC
7	ELECTRONIC LOCKING DEVICE POWER SUPPLIES - LOW VOLTAGE	SC	SC
8	ELECTRONIC LOCKING DEVICE POWER SUPPLY LOW VOLTAGE WIRING	SC	SC
9	ELECTRONIC LOCKING DEVICE POWER SUPPLY 120 VOLTAGE WIRING	EC	EC
10	DOOR CONTACTS	DH	DH
11	REQUEST TO EXIT DEVICES	DH	DH
12	CATEGORY CABLING FOR VIDEO SURVEILLANCE	SCC	SCC
13	NETWORK SWITCHES AND EQUIPMENT	O	O
14	EMERGENCY PHONES	SC	SC
15	REQUEST TO EXIT DEVICES (ABOVE DOOR)	SC	SC
16	NETWORK VIDEO RECORDER / SERVER AND ASSOCIATED SOFTWARE	SC	SC
17	VIDEO SURVEILLANCE CAMERA LICENSES	SC	SC
18	NETWORK VIDEO WORKSTATION AND MONITORS	O	O
19	CARD ACCESS BADGING WORKSTATION AND MONITORS	O	O
20	CARD ACCESS BADGING PRINTER	O	O

SECURITY DOOR SCHEDULE					
CONTRACTOR SHALL COORDINATE AND CONFIRM ALL SECURITY DOOR ROUGH-IN REQUIREMENTS WITH ARCHITECTURAL DOOR SCHEDULE AND DIVISION 08 DOOR HARDWARE SPECIFICATIONS.					
ROOM NUMBER	ROOM NAME	DOOR NUMBER	ACCESS CONTROL	REFERENCE DETAIL	NOTES
101	VESTIBULE	101A	CR	2Y801	
104	COMMUNITY LIVING ROOM	104	CR	5Y801	MULLION-MOUNTED CARD READER
105	MULTI-PURPOSE ROOM	105	CR	5Y801	MULLION-MOUNTED CARD READER
106	STORAGE	106	CR	2Y801	
107	ELECTRICAL	107	CR	5Y801	
113	RESTROOM	113	DC	3Y801	
114	JC	114	CR	5Y801	
115	IT/AV	115	CR	5Y801	
117	OFFICE	117	CR	5Y801	
118	MEETING	118	CR	5Y801	MULLION-MOUNTED CARD READER
119	CORRIDOR	119	CR	5Y801	
121	RESTROOM	121	DC	3Y801	
151	VESTIBULE	151	CR	2Y801	
156	DRESSING ROOM	156	CR	5Y801	
159	OFFICE	158	CR	5Y801	
158	JC	159	CR	5Y801	
161	ELECTRICAL	161	CR	5Y801	
162	STORAGE	162	CR	2Y801	
163	MECHANICAL/ PLUMBING	163	CR	5Y801	
164	AV	164	CR	5Y801	
165	BAR	165	CR	5Y801	
166	CATERING KITCHEN	166	CR	5Y801	
167	BAR	167	CR	5Y801	
168	CORRIDOR	168	CR	2Y801	
169	BALLROOM	169	CR	2Y801	
169	BALLROOM	169A	CR	3Y801	MULLION-MOUNTED CARD READER
170	BALLROOM	170	CR	2Y801	
170	BALLROOM	170A	CR	5Y801	MULLION-MOUNTED CARD READER
112	MECHANICAL	174	CR	5Y801	

ROOM NUMBER	ROOM NAME	DEVICE NUMBER	CAMERA TYPE	MAKE & MODEL	TERMINATION POINT	REFERENCE DETAIL	NOTES
101	VESTIBULE	C-101-1	FIX	HANWHA XNV-A6084R	115	6/Y801	
102	RECEPTION	C-640-1	360	HANWHA QNF-9010	115	6/Y801	
104	COMMUNITY LIVING ROOM	C-104-1	DUO	HANWHA PNM-7082RVD	115	6/Y801	
105	MULTI PURPOSE ROOM	C-105-1	DUO	HANWHA PNM-7082RVD	115	6/Y801	
119	CORRIDOR	C-119-1	DUO	HANWHA PNM-7082RVD	115	6/Y801	
151	VESTIBULE	C-152-1	180	HANWHA QNF-9010	164	6/Y801	
164	AV	C-164-1	180	HANWHA QNF-9010	164	6/Y801	
165	BAR	C-165-1	FIX	HANWHA XNV-A6084R	164	1/Y801	
167	BAR	C-167-1	FIX	HANWHA XNV-A6084R	164	1/Y801	
168	CORRIDOR	C-168-1	360	HANWHA QNF-9010	164	1/Y801	
169	BALLROOM	C-169-1	270	HANWHA QNF-9010	164	6/Y801	
170	BALLROOM	C-170-1	270	HANWHA QNF-9010	164	6/Y801	
EXT	EXTERIOR	C-EXT-6	270	HANWHA QNF-9010	164	7/Y801	
EXT	EXTERIOR	C-EXT-1	270	HANWHA QNF-9010	115	7/Y801	
EXT	EXTERIOR	C-EXT-2	270	HANWHA QNF-9010	115	7/Y801	
EXT	EXTERIOR	C-EXT-3	270	HANWHA QNF-9010	115	7/Y801	
EXT	EXTERIOR	C-EXT-4	270	HANWHA QNF-9010	164	7/Y801	
EXT	EXTERIOR	C-EXT-5	270	HANWHA QNF-9010	164	7/Y801	
EXT	EXTERIOR	C-EXT-7	270	HANWHA QNF-9010	164	2/Y801	
EXT	EXTERIOR	C-EXT-8	360	HANWHA QNF-9010	115	8/Y801	
EXT	EXTERIOR	C-EXT-9	360	HANWHA QNF-9010	164	8/Y801	
EXT	EXTERIOR	C-EXT-10	360	HANWHA QNF-9010	164	8/Y801	
EXT	EXTERIOR	C-EXT-11	360	HANWHA QNF-9010	164	8/Y801	
EXT	EXTERIOR	C-EXT-12	360	HANWHA QNF-9010	115	8/Y801	
EXT	EXTERIOR	C-EXT-13	360	HANWHA QNF-9010	164	8/Y801	

SECURITY DEVICE SCHEDULE							
ROOM NUMBER	ROOM NAME	DEVICE NUMBER	DEVICE TYPE	MAKE & MODEL	TERMINATION POINT	REFERENCE DETAIL	NOTES
102	RECEPTION	PB-102	PB		115	4/Y801	
115	IT/AV	ACP-115	ACP		115	N/A	
115	IT/AV	PS-115	PS		115	N/A	
164	AV	ACP-164	ACP		164	N/A	
164	AV	PS-164	PS		164	N/A	
165	BAR	PB-165	PB		164	4/Y801	
167	BAR	PB-167	PB		164	4/Y801	

fishbeck
Engineers | Architects | Scientists | Constructors

REVISIONS		
10/27/2026	A2	ADDENDUM 02

10/12/2026 BID AND PERMIT SET

Drawn By	TGAUNTNER
Designer	JFISHMAN, TROBINETTE
Reviewer	DCHITTY, KKERSTETTER
Manager	CKRETOVIC

Hard copy is intended to be 24"x36" when plotted. Scale(s) indicated and graphic quality may not be accurate for any other size.

PROJECT NO.


2500281

SHEET NO.

Y001


©Copyright 2026
All Rights Reserved

PLOT INFO: 10/26/2026 12:59:21 PM Autodesk Docs://2500281 - Van Buren Twp Lake House2026_T_2500281.rvt

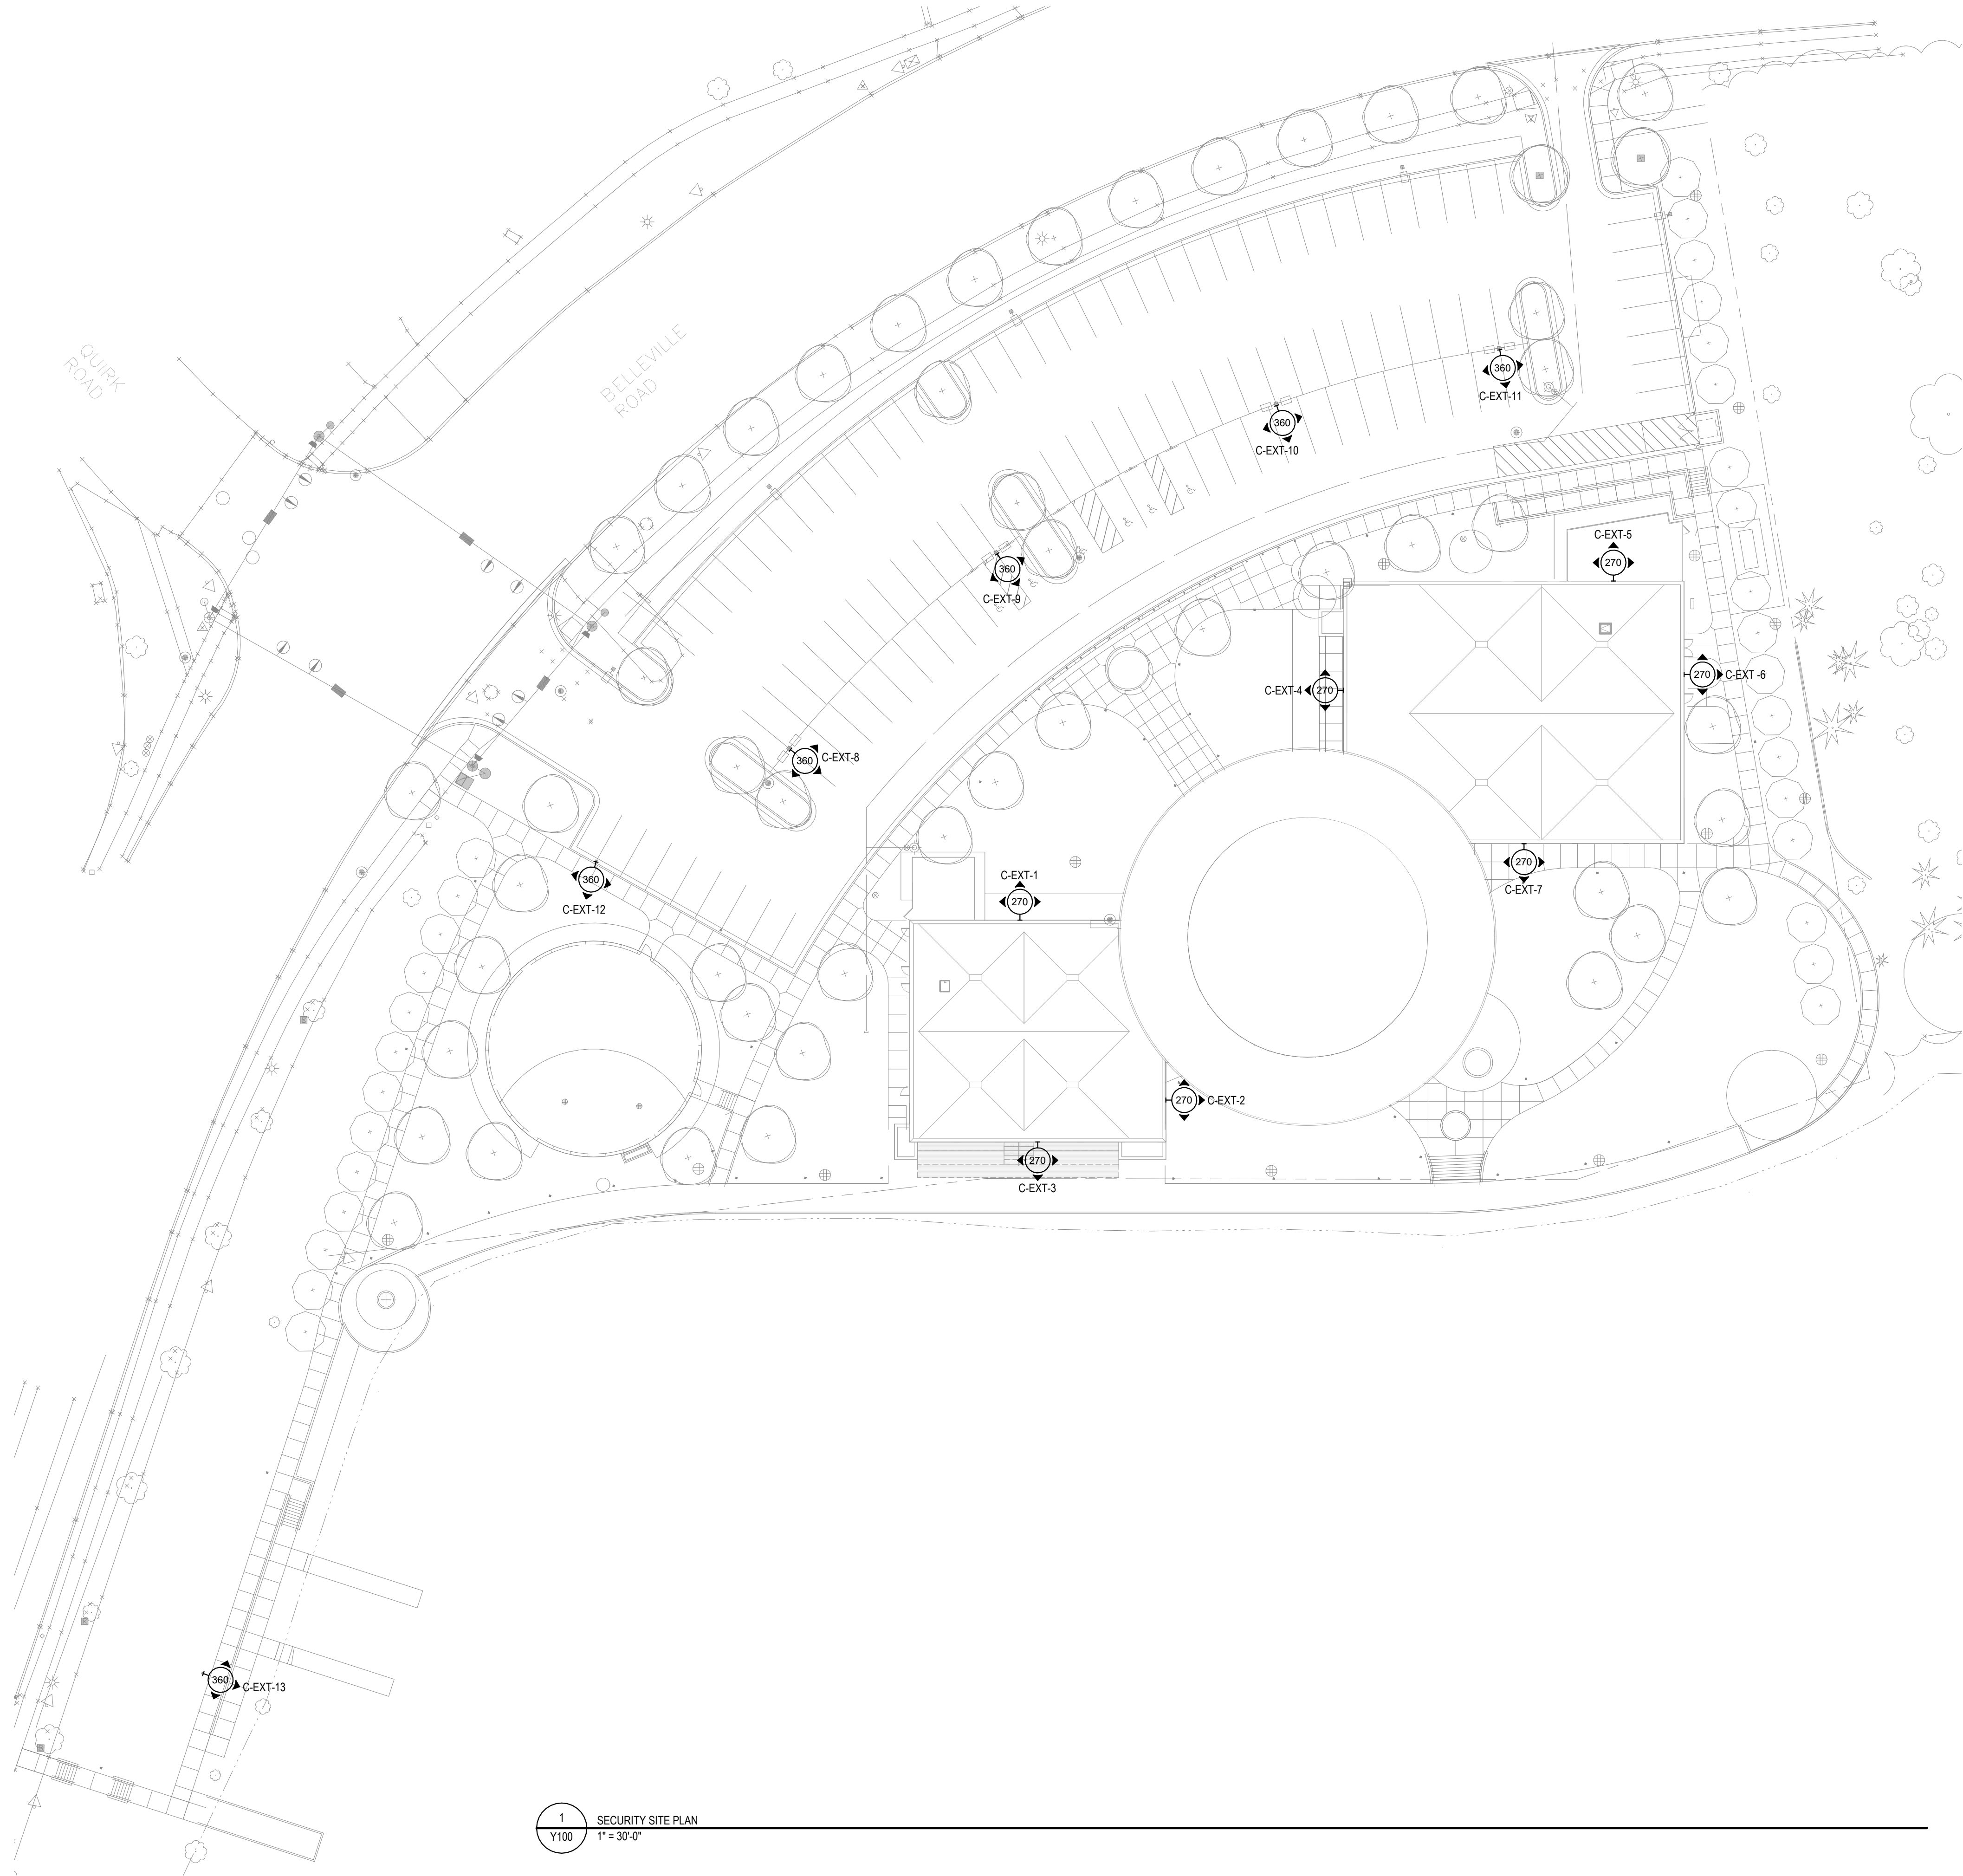

1 SECURITY SITE PLAN
Y100
1" = 30'-0"

KEY PLAN

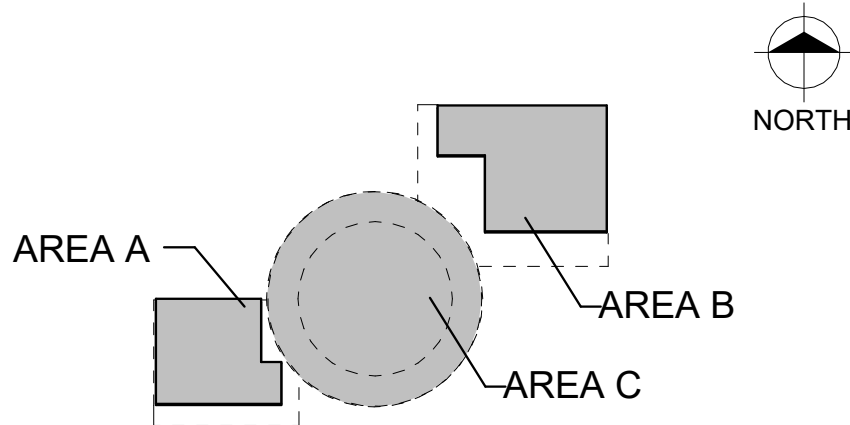

Van Buren Charter Township
Van Buren Township, MI
The Lakeside Park

REVISIONS

Drawn By	TGAUNTNER
Designer	JFISHMAN, TROBINETTE
Reviewer	DCHITTY, KKERSTETTER
Manager	CKRETOVIC

Hard copy is intended to be 24"x36" when plotted. Scale(s) indicated and graphic quality may not be accurate for any other size.


PROJECT NO.
2500281

SHEET NO.

Y100


©Copyright 2026
All Rights Reserved

PLOT INFO: 10/26/2026 12:59:23 PM Autodesk Docs://2500281 - Van Buren Twp Lake House2026_T_2500281.rvt

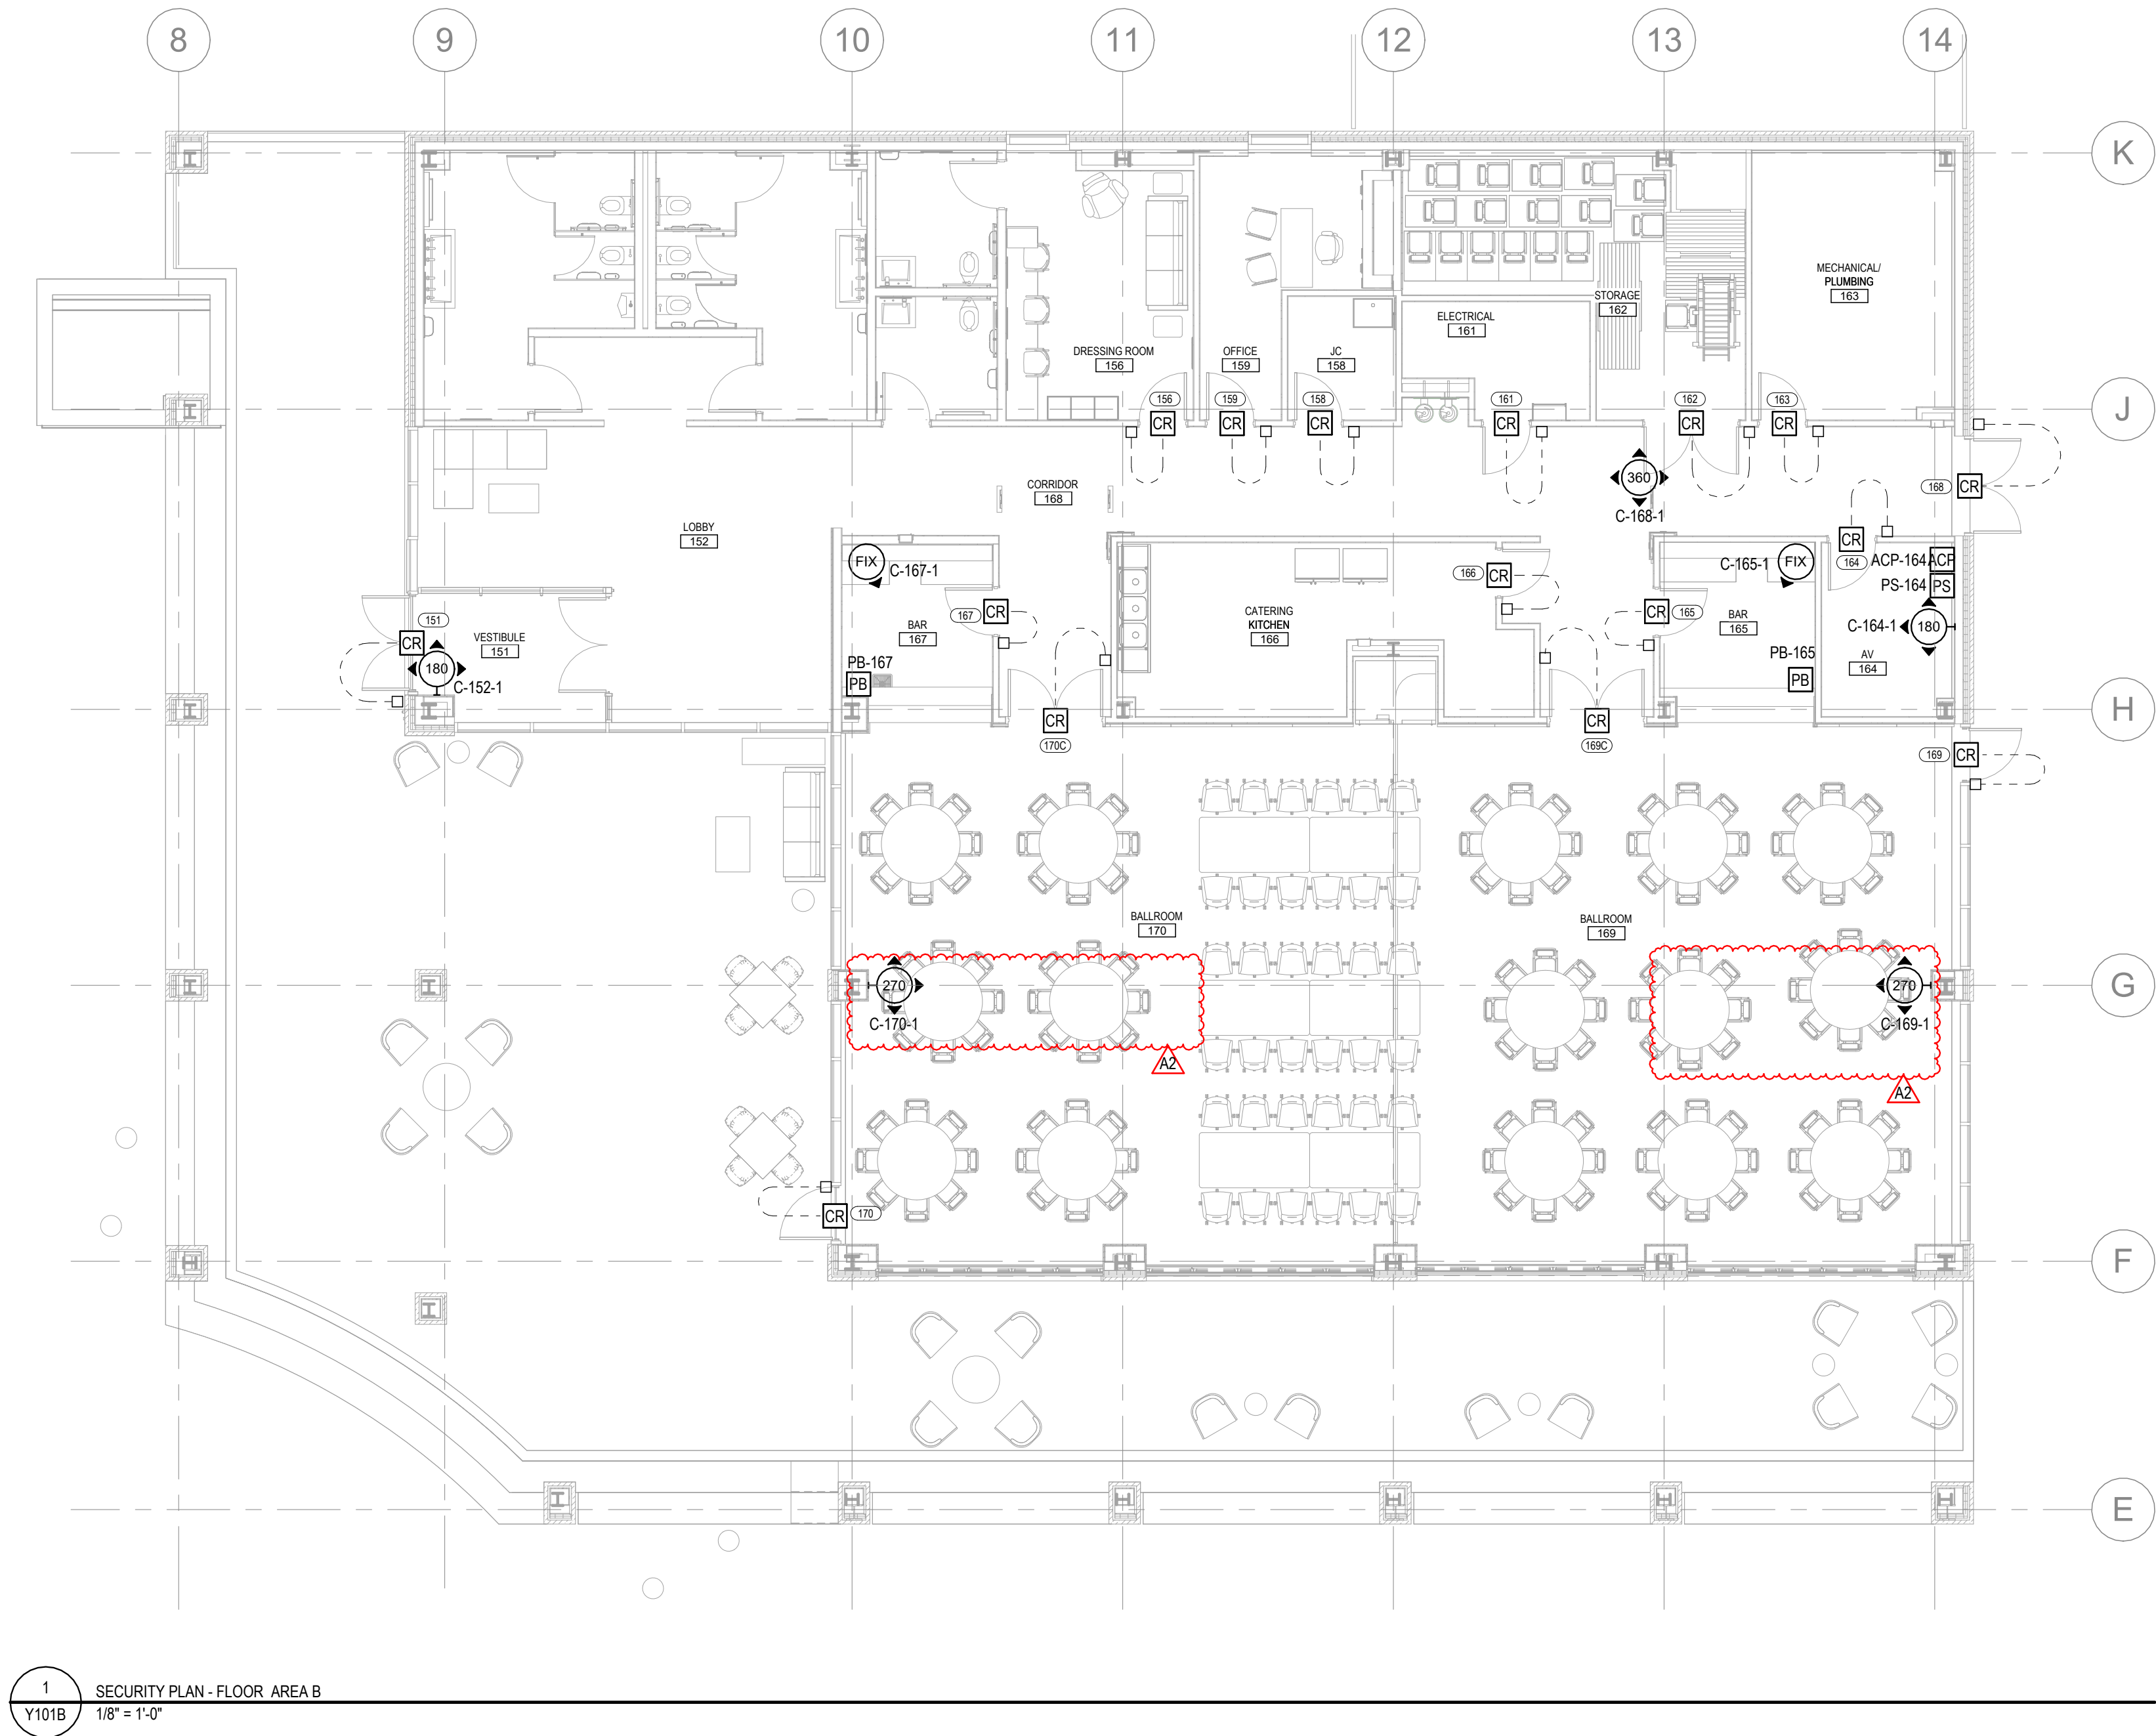

SHEET NOTES - SECURITY	
1	REFER TO SHEET Y001 FOR ALL SECURITY GENERAL NOTES, LEGENDS, ABBREVIATIONS, AND SHEET INDEX.

KEY PLAN

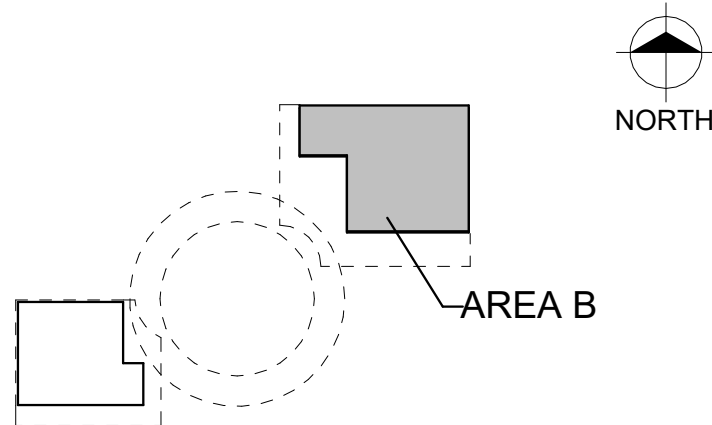

Van Buren Charter Township
Van Buren Township, MI
The Lakeside Park

REVISIONS		
10/27/2026	A2	ADDENDUM 02


10/12/2026	BID AND PERMIT SET
Drawn By	TGAUNTNER
Designer	JFISHMAN, TROBINETTE
Reviewer	DCHITTY, KKERSTETTER
Manager	CKRETOVIC

Hard copy is intended to be 24"x36" when plotted. Scale(s) indicated and graphic quality may not be accurate for any other size.

PROJECT NO.
2500281
SHEET NO.


Y101B

©Copyright 2026
All Rights Reserved

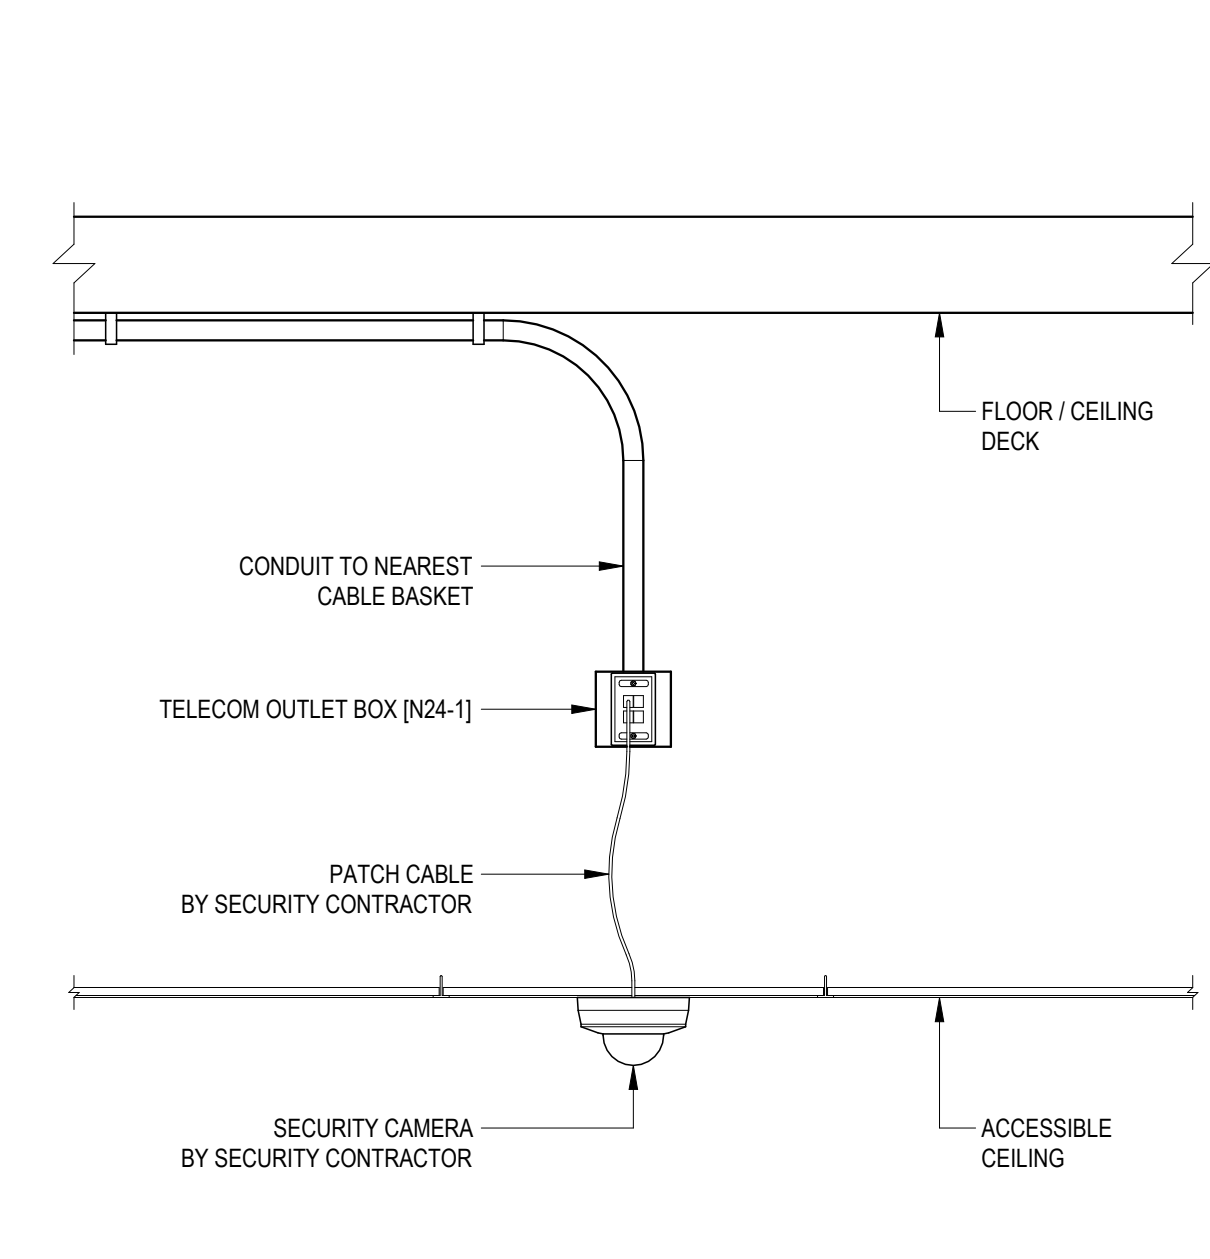


- NOTES:
1. UNLESS OTHERWISE INDICATED GENERAL CONTRACTOR TO PROVIDE ALL ELEMENTS SHOWN.
 2. SEE THE TELECOM TYPICAL CONDUIT RISER FOR CONDUIT REQUIREMENTS.


1
Y801 ACCESSIBLE CEILING FLUSH MOUNT CAMERA
NTS

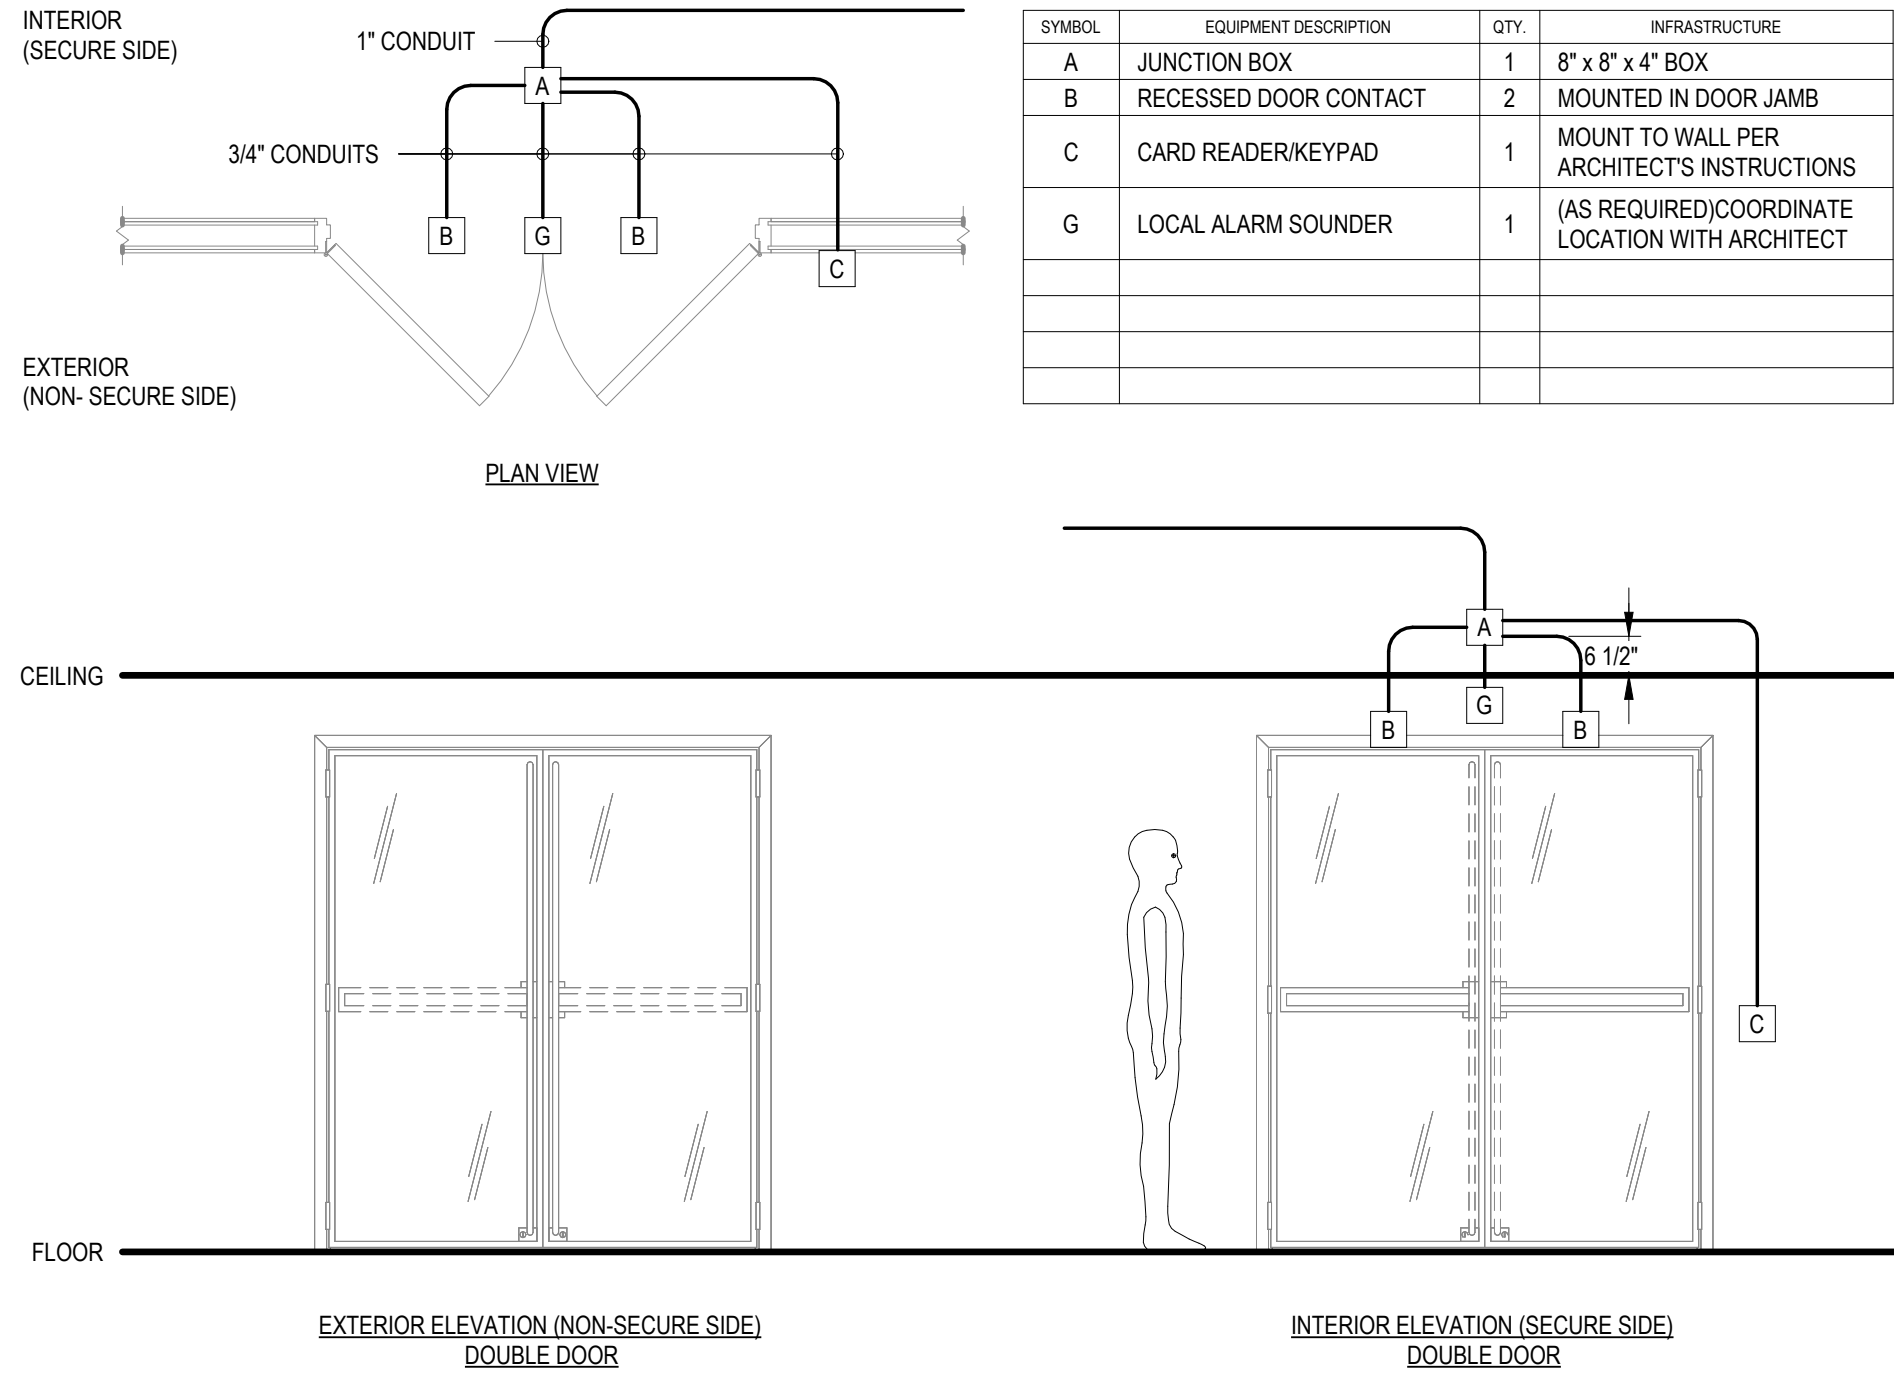

2
Y801 DOUBLE DOORS WICARD READER & MONITORING
NTS

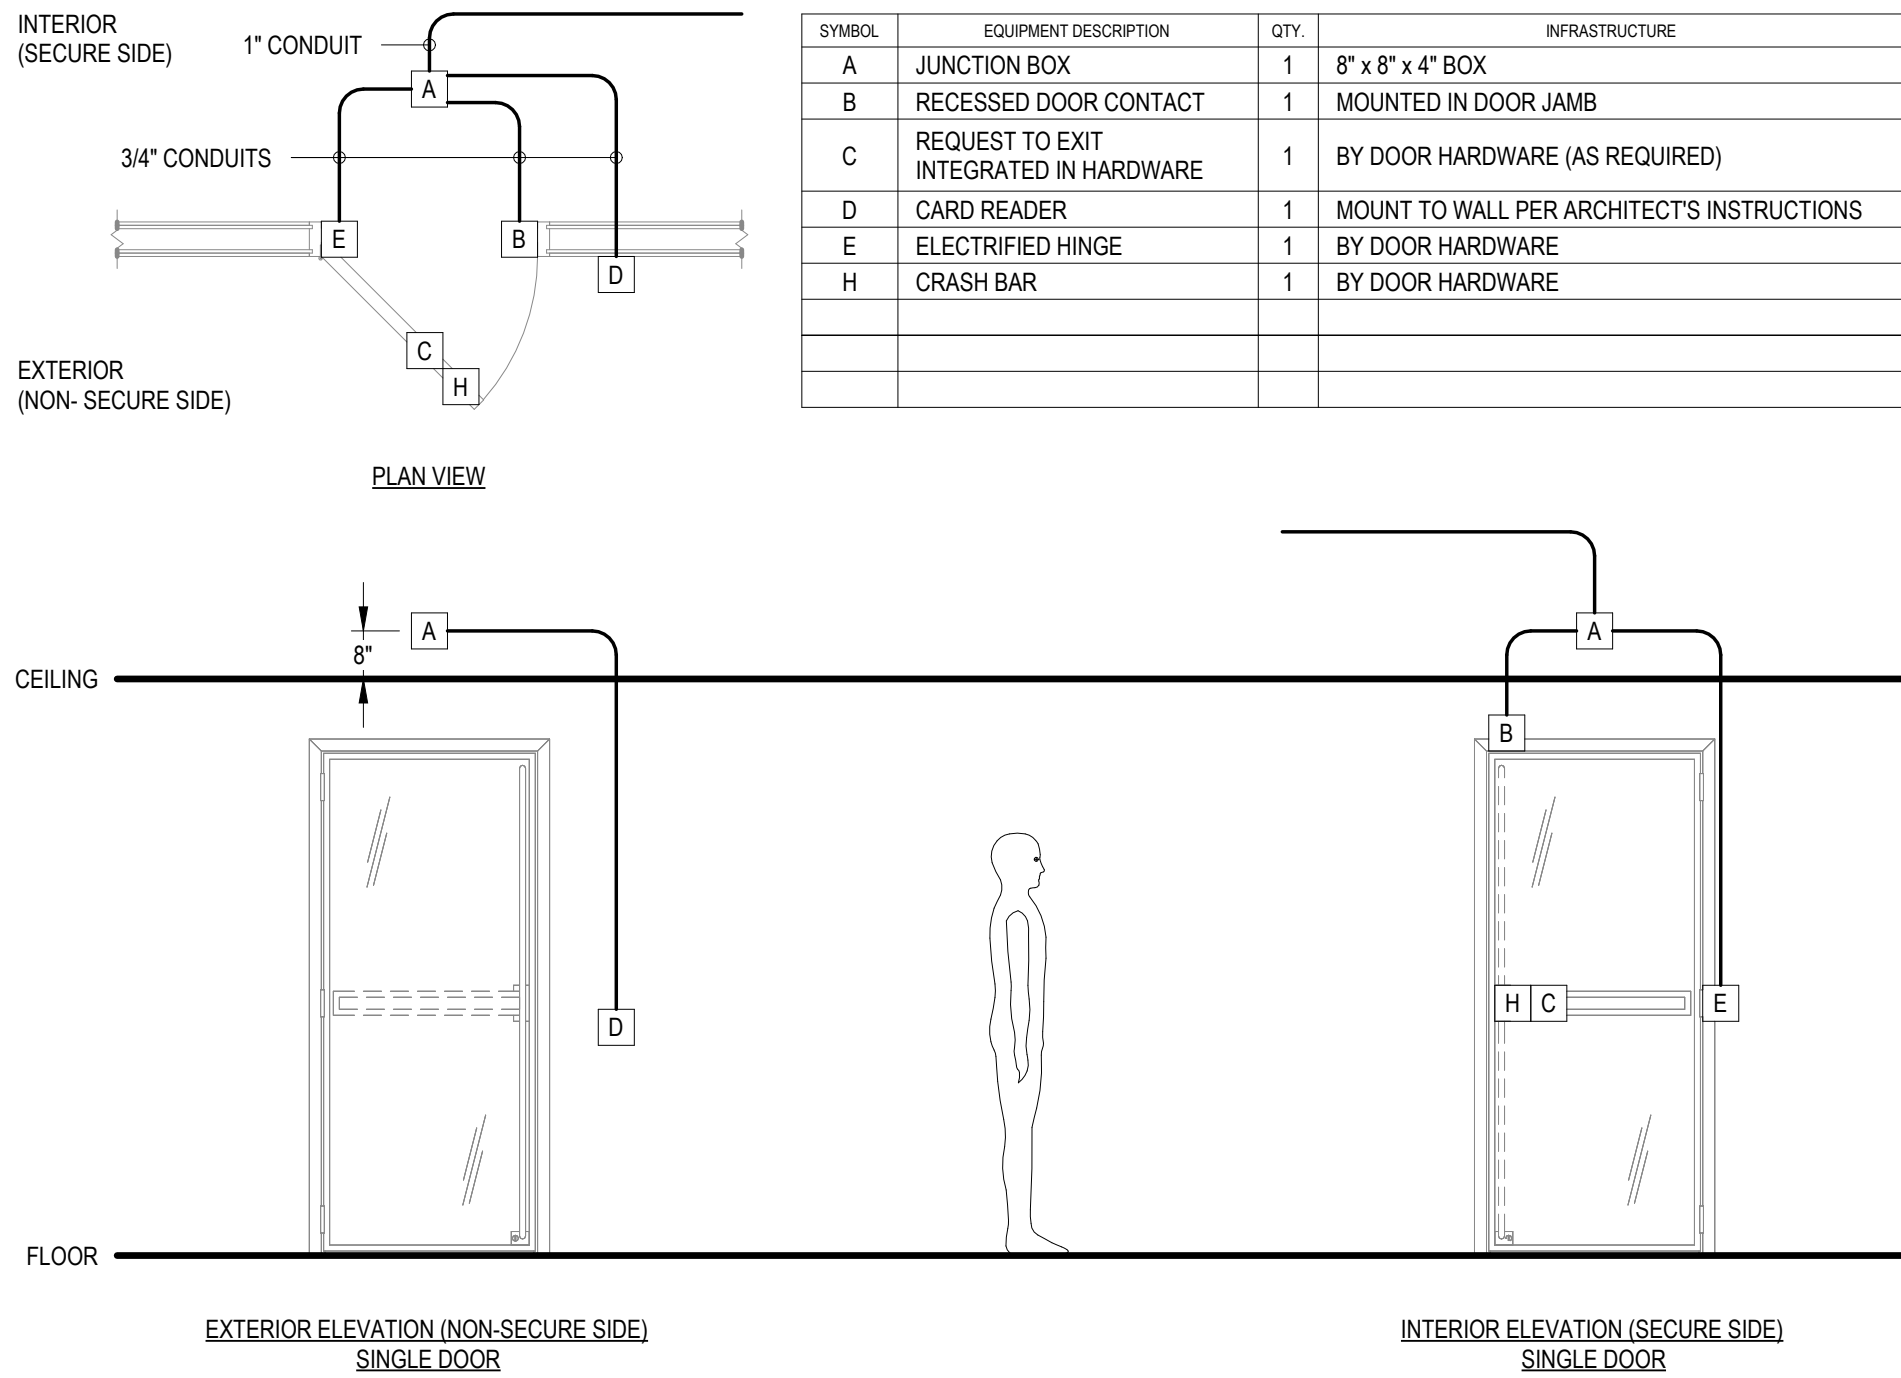


5
Y801 SINGLE DOOR - WITH CARD READER
NTS

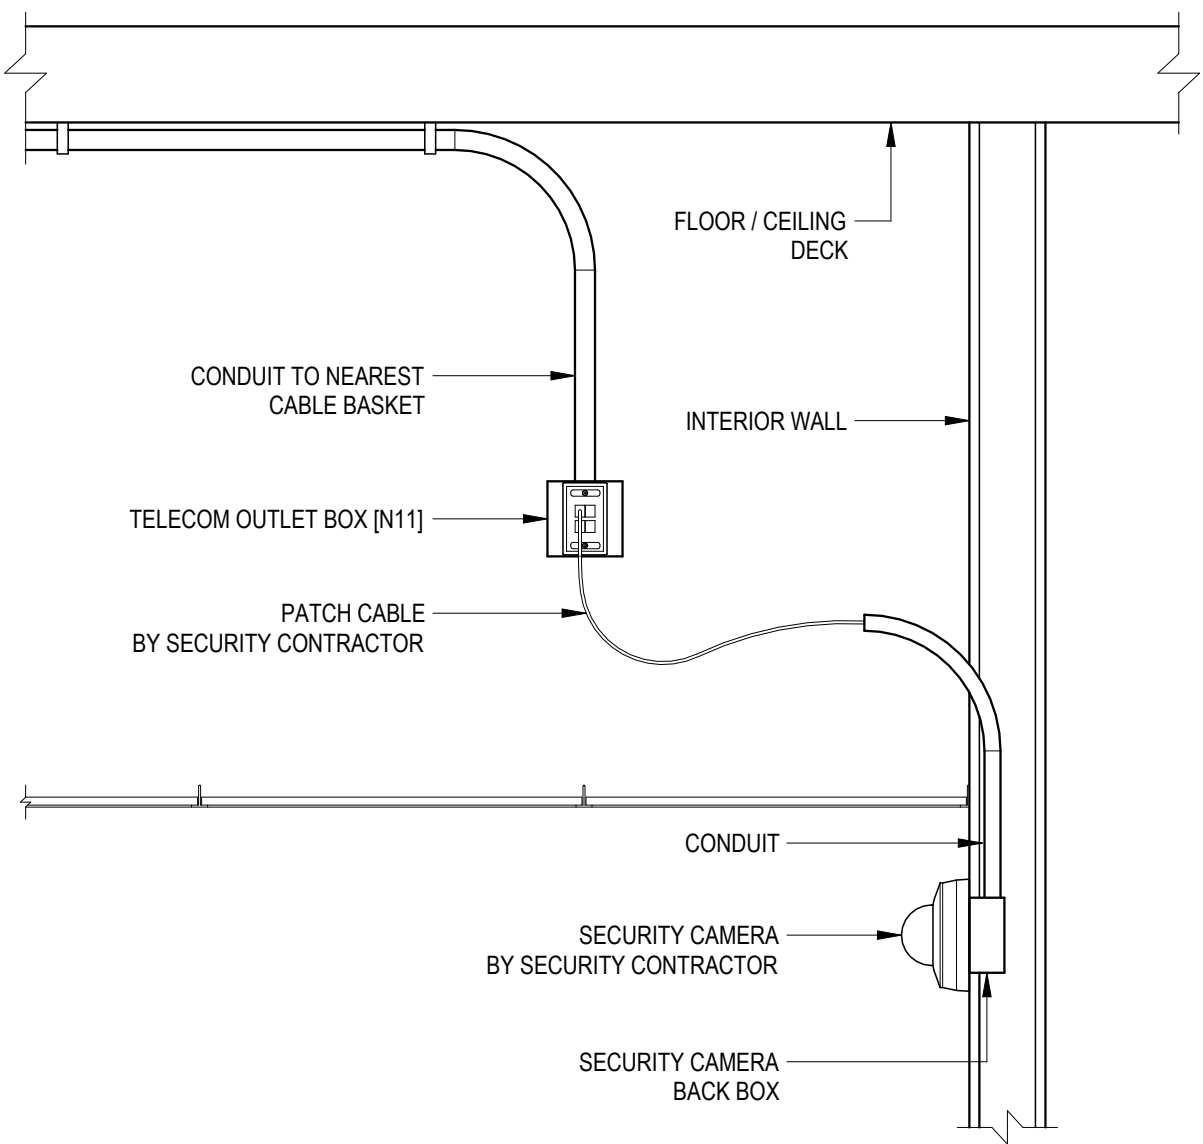


- NOTES:
1. UNLESS OTHERWISE INDICATED GENERAL CONTRACTOR TO PROVIDE ALL ELEMENTS SHOWN.
 2. SEE THE TELECOM TYPICAL CONDUIT RISER FOR CONDUIT REQUIREMENTS.

6
Y801 INTERIOR WALL FLUSH MOUNT CAMERA
1" = 1'-0"

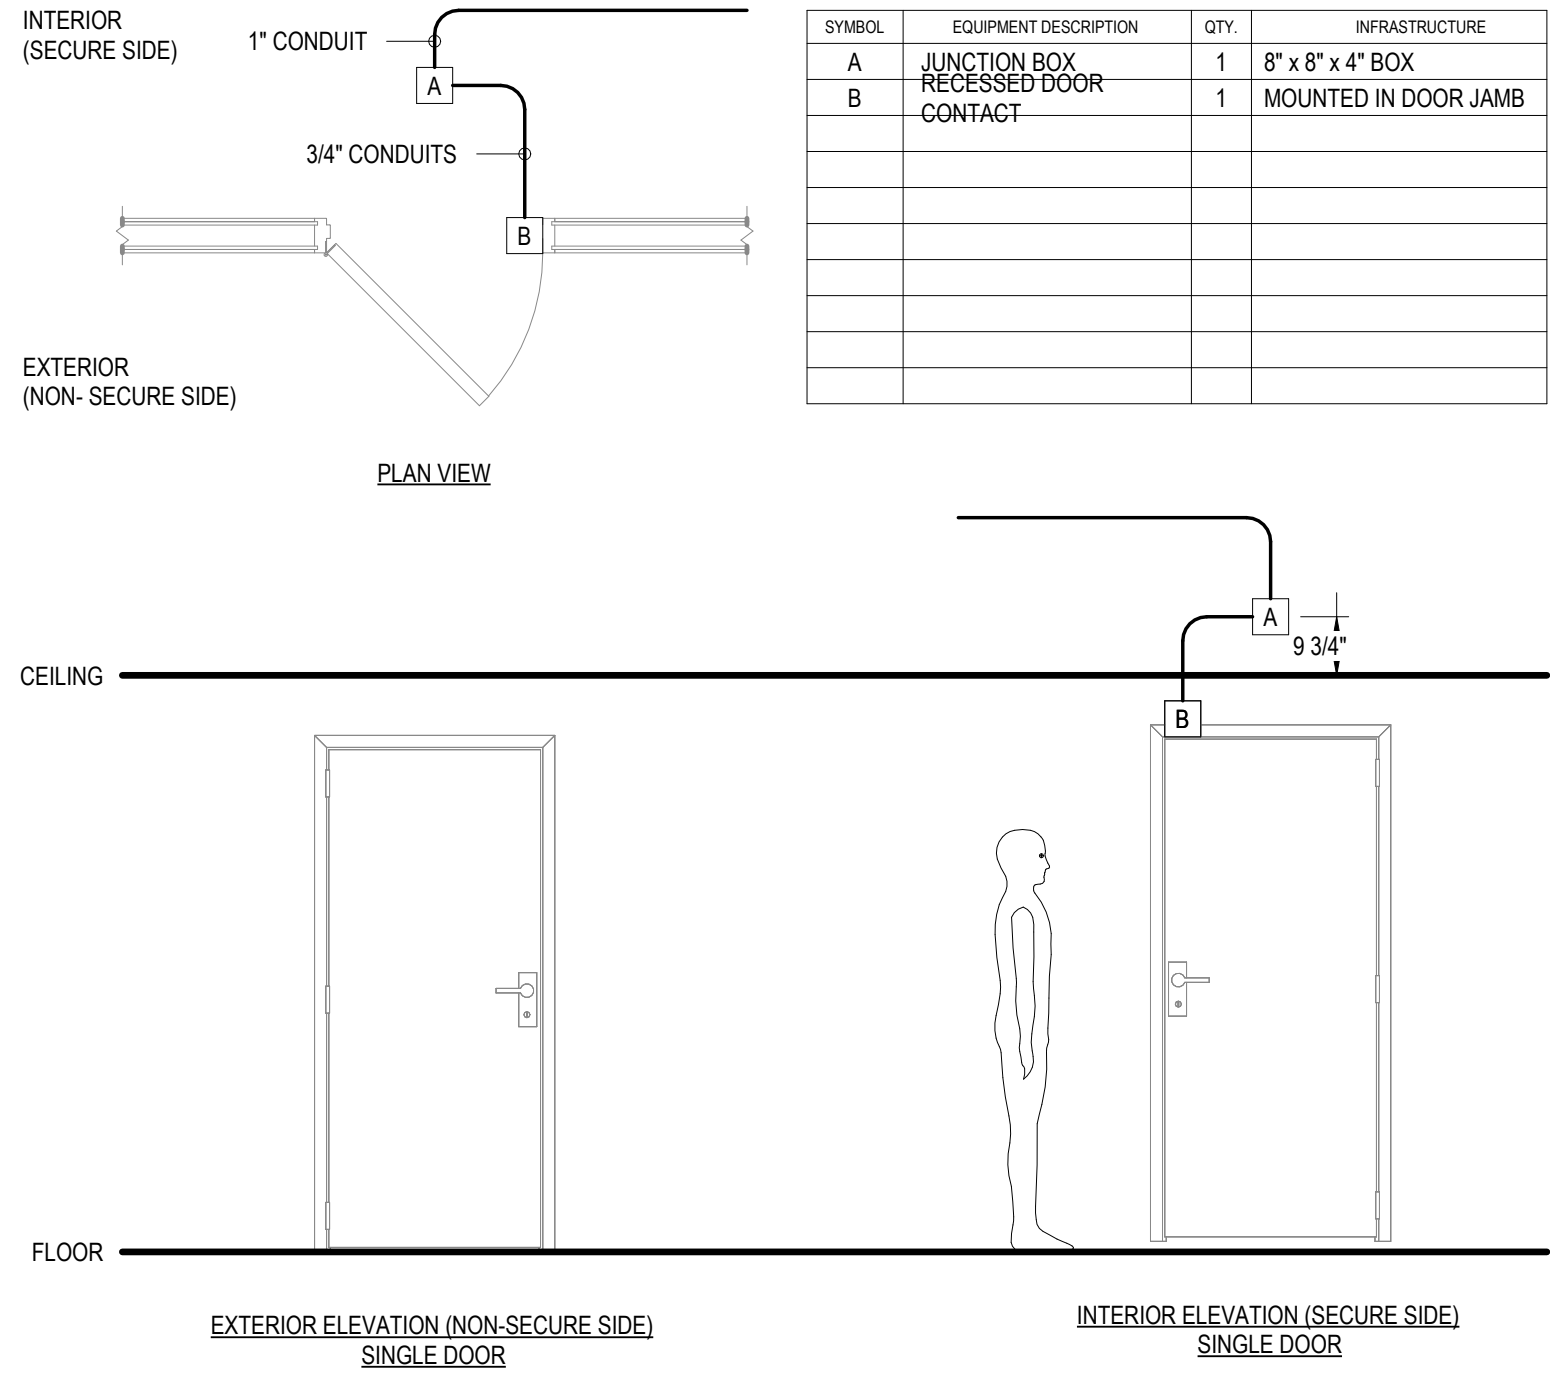


3
Y801 SINGLE DOOR WIMONITORING
NTS

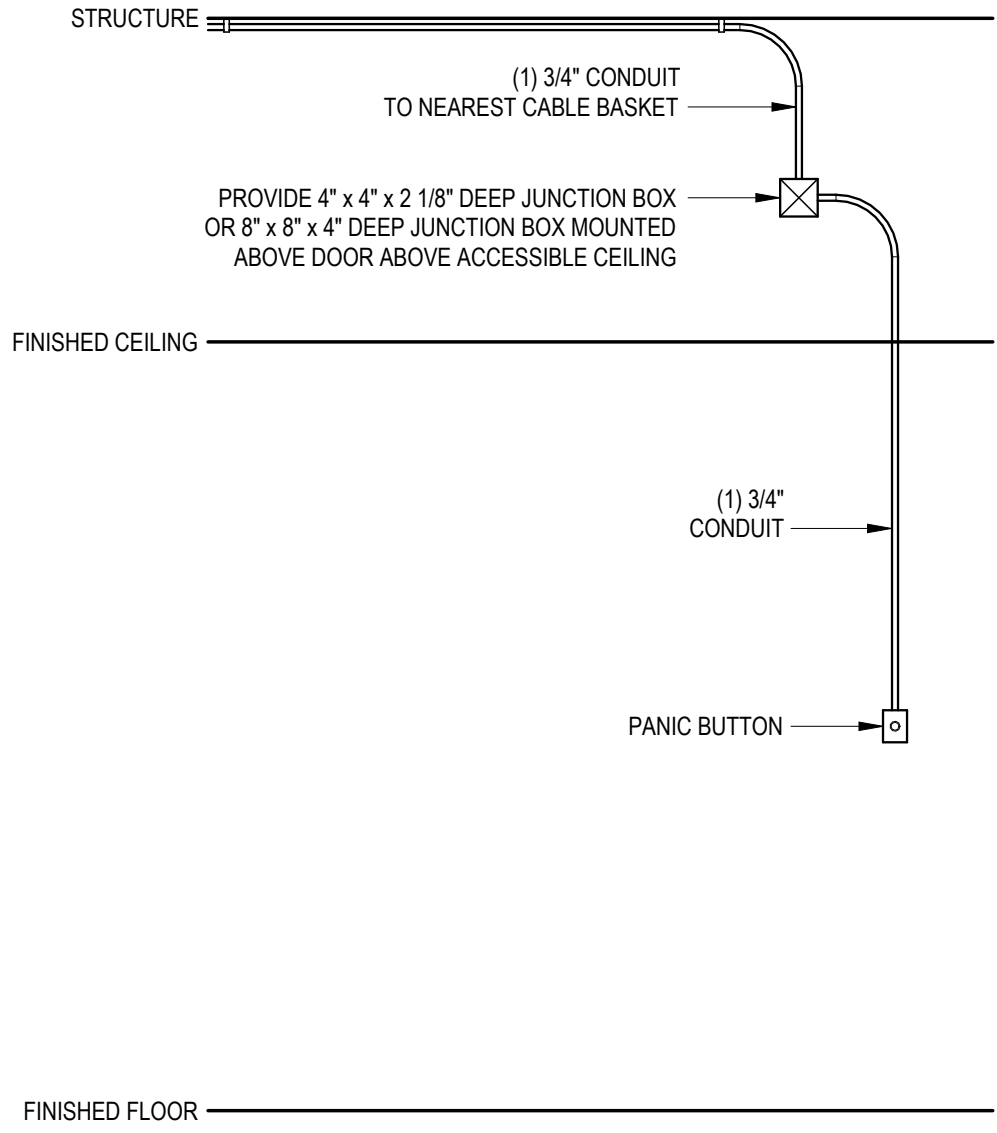


- NOTES:
1. REVIEW PANIC BUTTON LOCATION WITH THE SECURITY CONSULTANT AND ARCHITECT PRIOR TO INSTALLATION.

4
Y801 INTERIOR WALL MOUNTED PANIC BUTTON
NTS

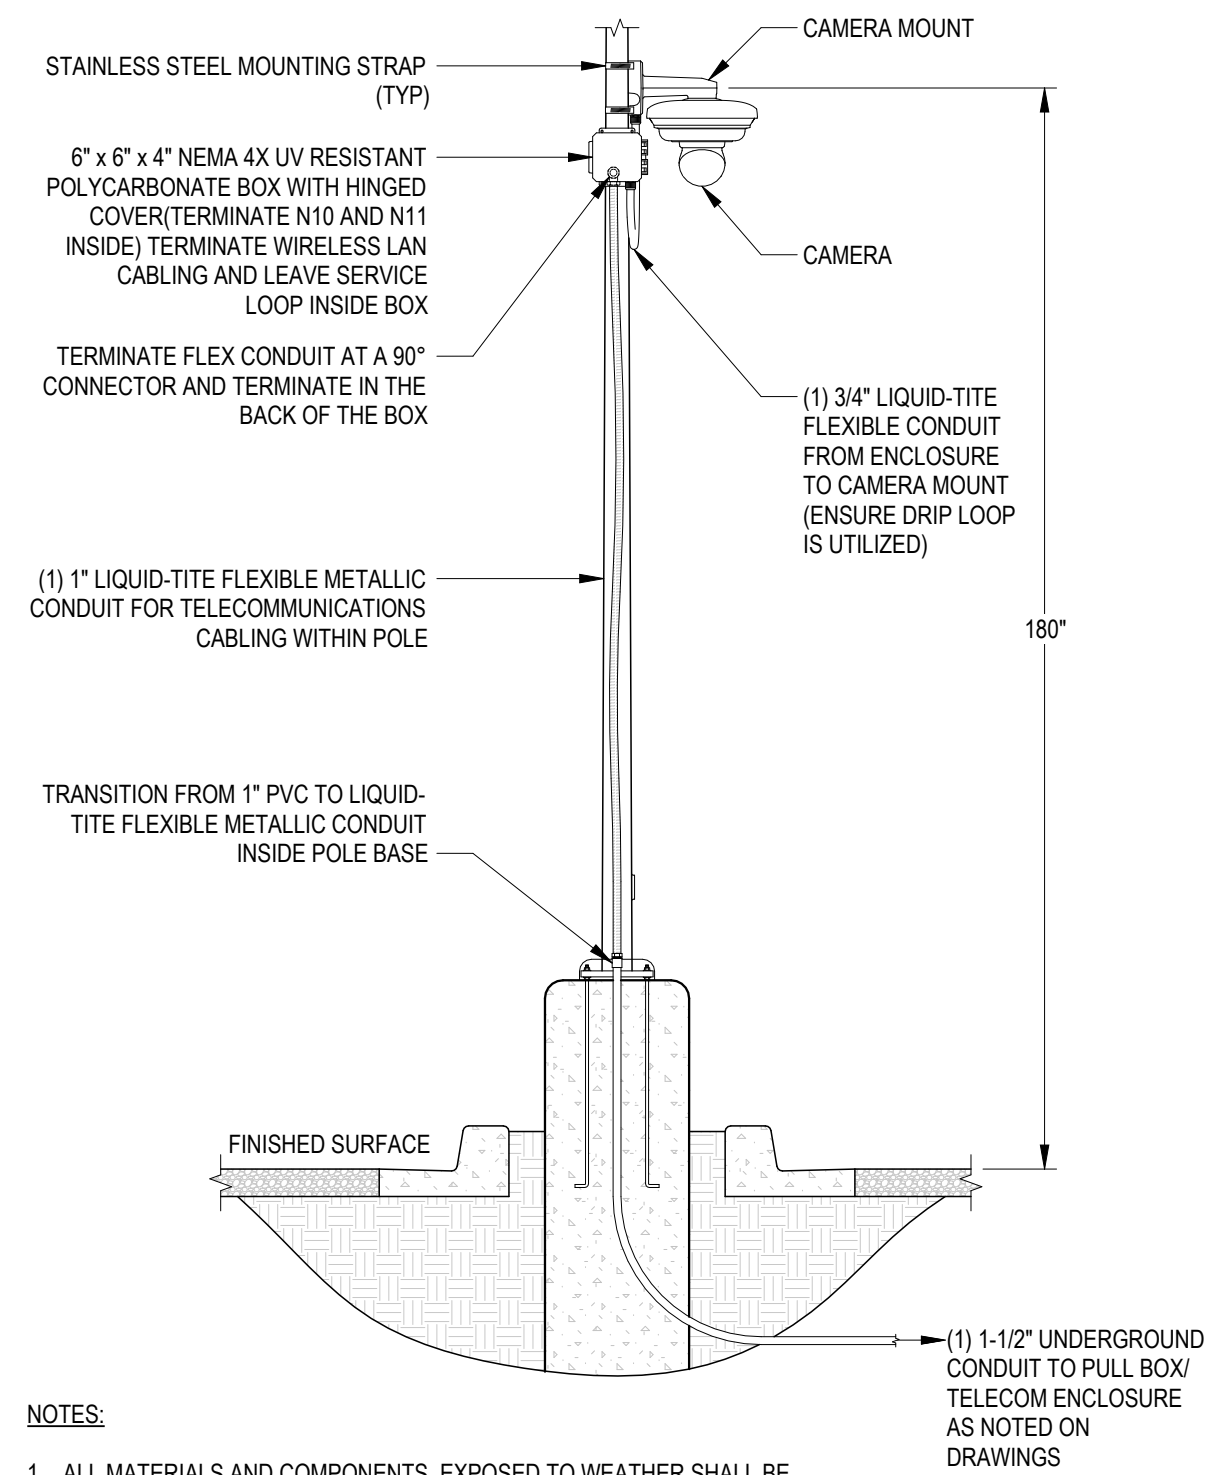

- NOTES:
1. ALL MATERIALS AND COMPONENTS EXPOSED TO WEATHER SHALL BE WEATHERPROOF AND ALL MOUNTING HARDWARE SHALL BE STAINLESS STEEL.
 2. COORDINATE EXACT CAMERA PLACEMENT/VIEW ANGLE WITH OWNER.
 3. CONFIRM COLOR AND PAINT BOXES, COVERS AND ATTACHMENT HARDWARE AS REQUIRED.

7
Y801 POLE MOUNT CAMERA
3/8" = 1'-0"

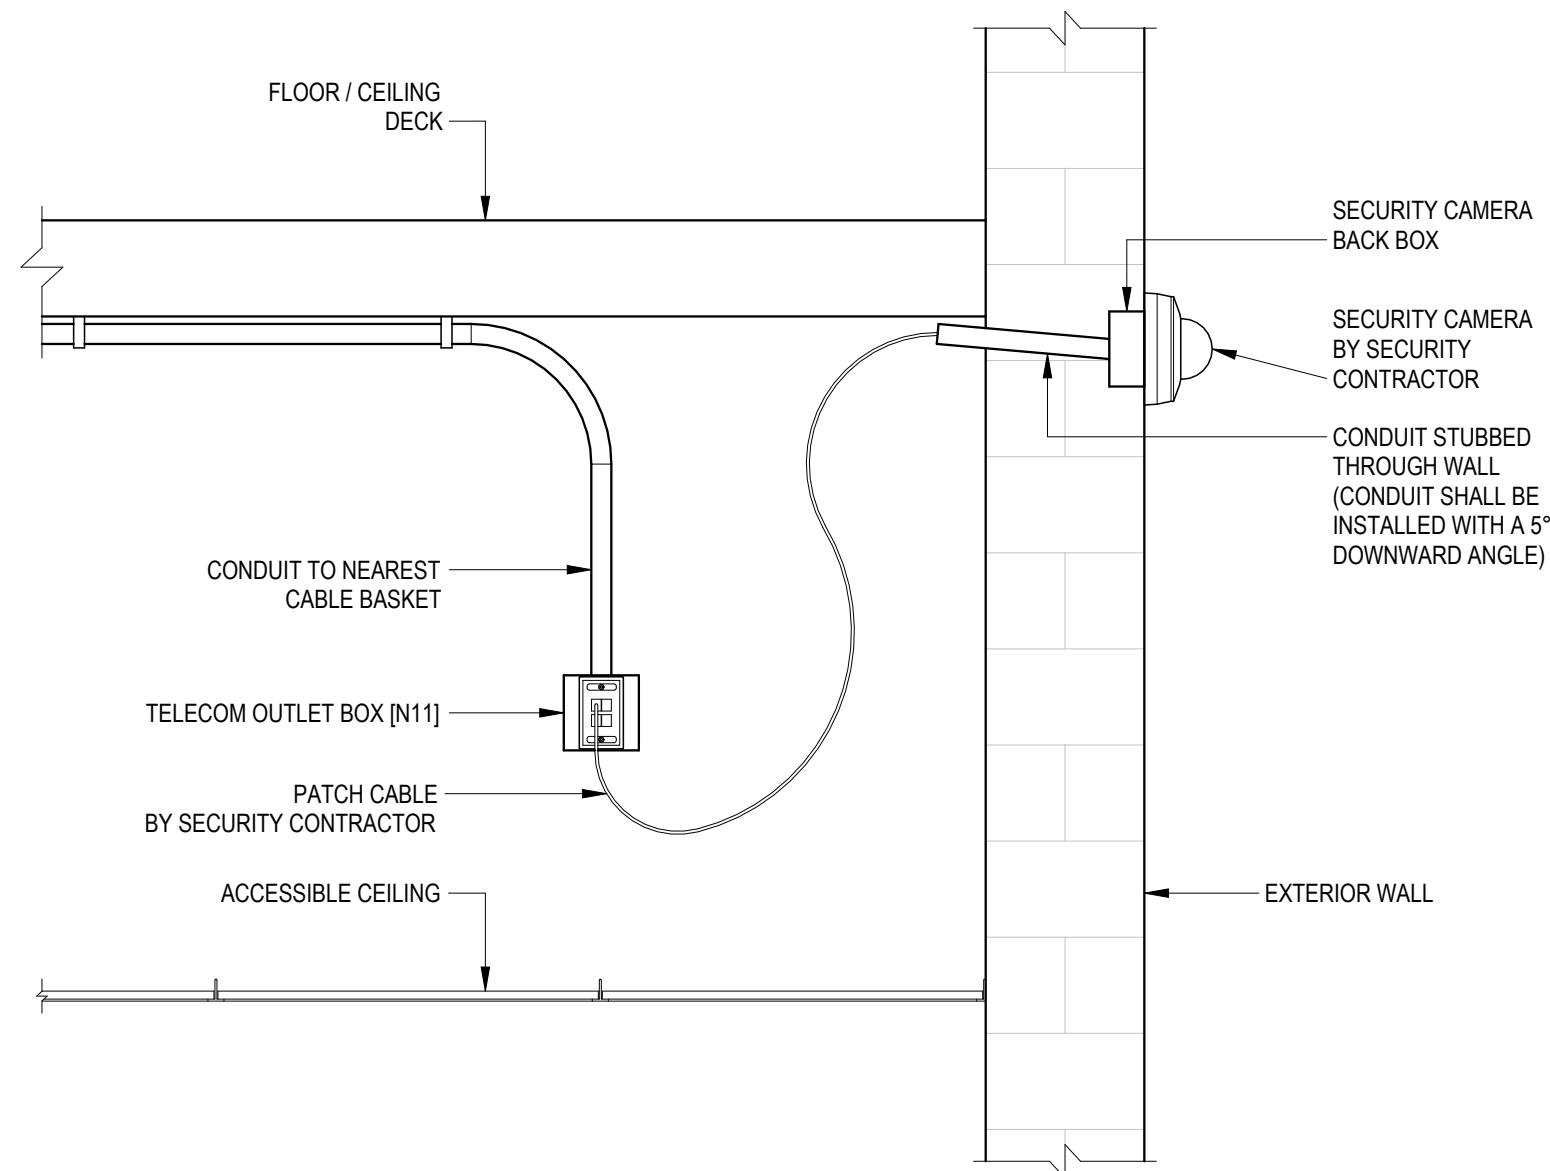

- NOTES:
1. UNLESS OTHERWISE INDICATED GENERAL CONTRACTOR TO PROVIDE ALL ELEMENTS SHOWN.
 2. SEE THE TELECOM TYPICAL CONDUIT RISER FOR CONDUIT REQUIREMENTS.

8
Y801 EXTERIOR WALL FLUSH MOUNT CAMERA
1" = 1'-0"

Van Buren Charter Township

Van Buren Township, MI

The Lakeside Park

fishbeck
Engineers | Architects | Scientists | Constructors

REVISIONS		
10/27/2026	A2	ADDENDUM 02


10/12/2026 BID AND PERMIT SET	
Drawn By	TGAUNTNER
Designer	JFISHMAN, TROBINETTE
Reviewer	DCHITTY, KKERSTETTER
Manager	CKRETOVIC

Hard copy is intended to be 24"x36" when plotted. Scale(s) indicated and graphic quality may not be accurate for any other size.


PROJECT NO.
2500281

SHEET NO.

Y801

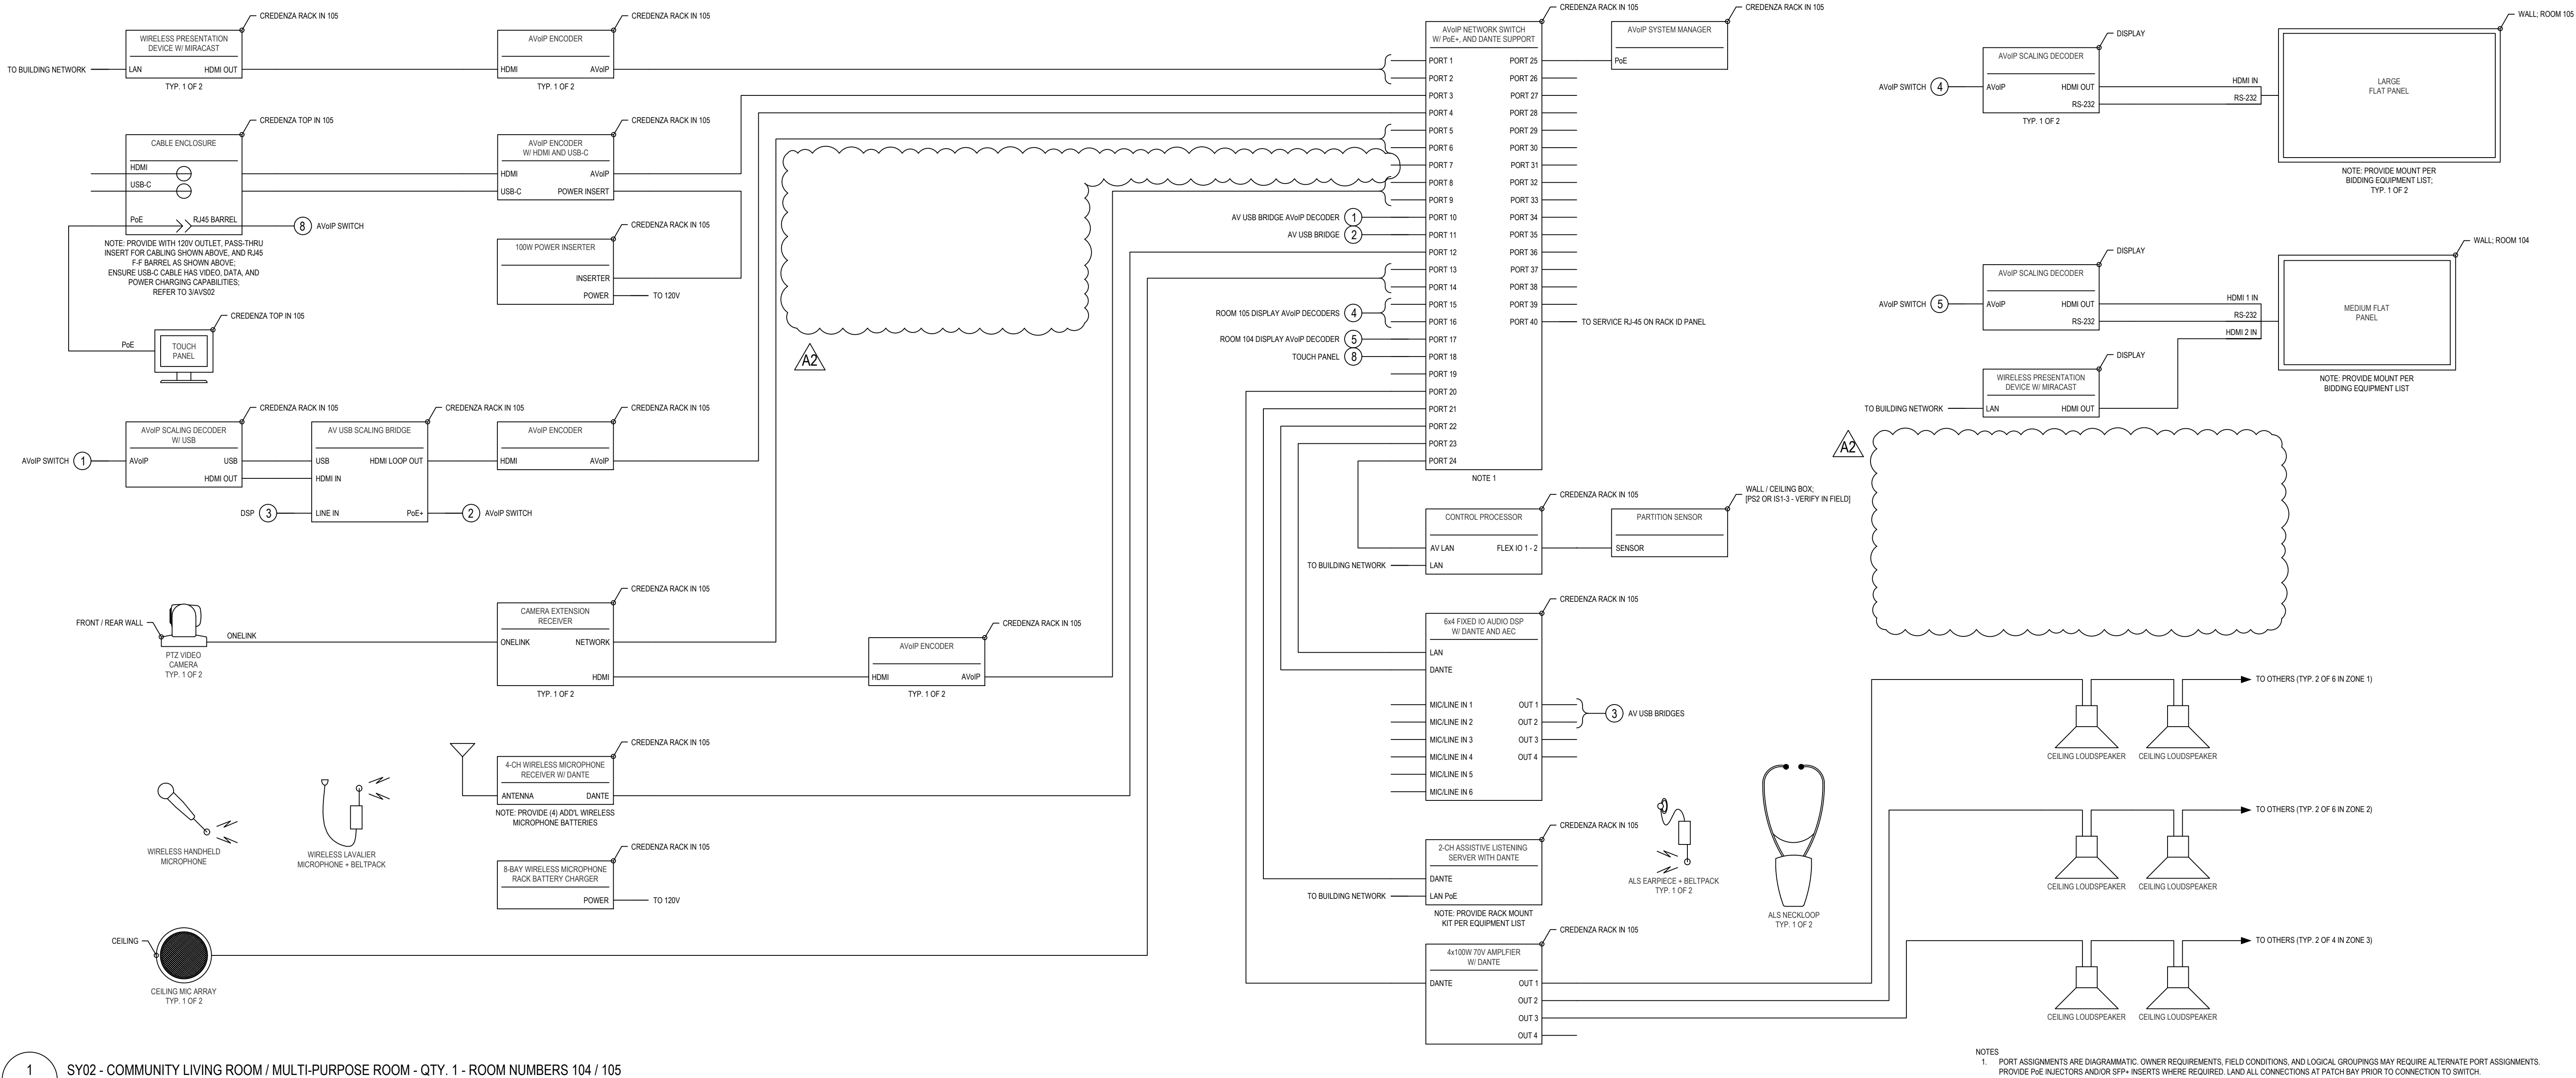

1
AVS02 SY02 - COMMUNITY LIVING ROOM / MULTI-PURPOSE ROOM - QTY. 1 - ROOM NUMBERS 104 / 105
SCALE: NTS

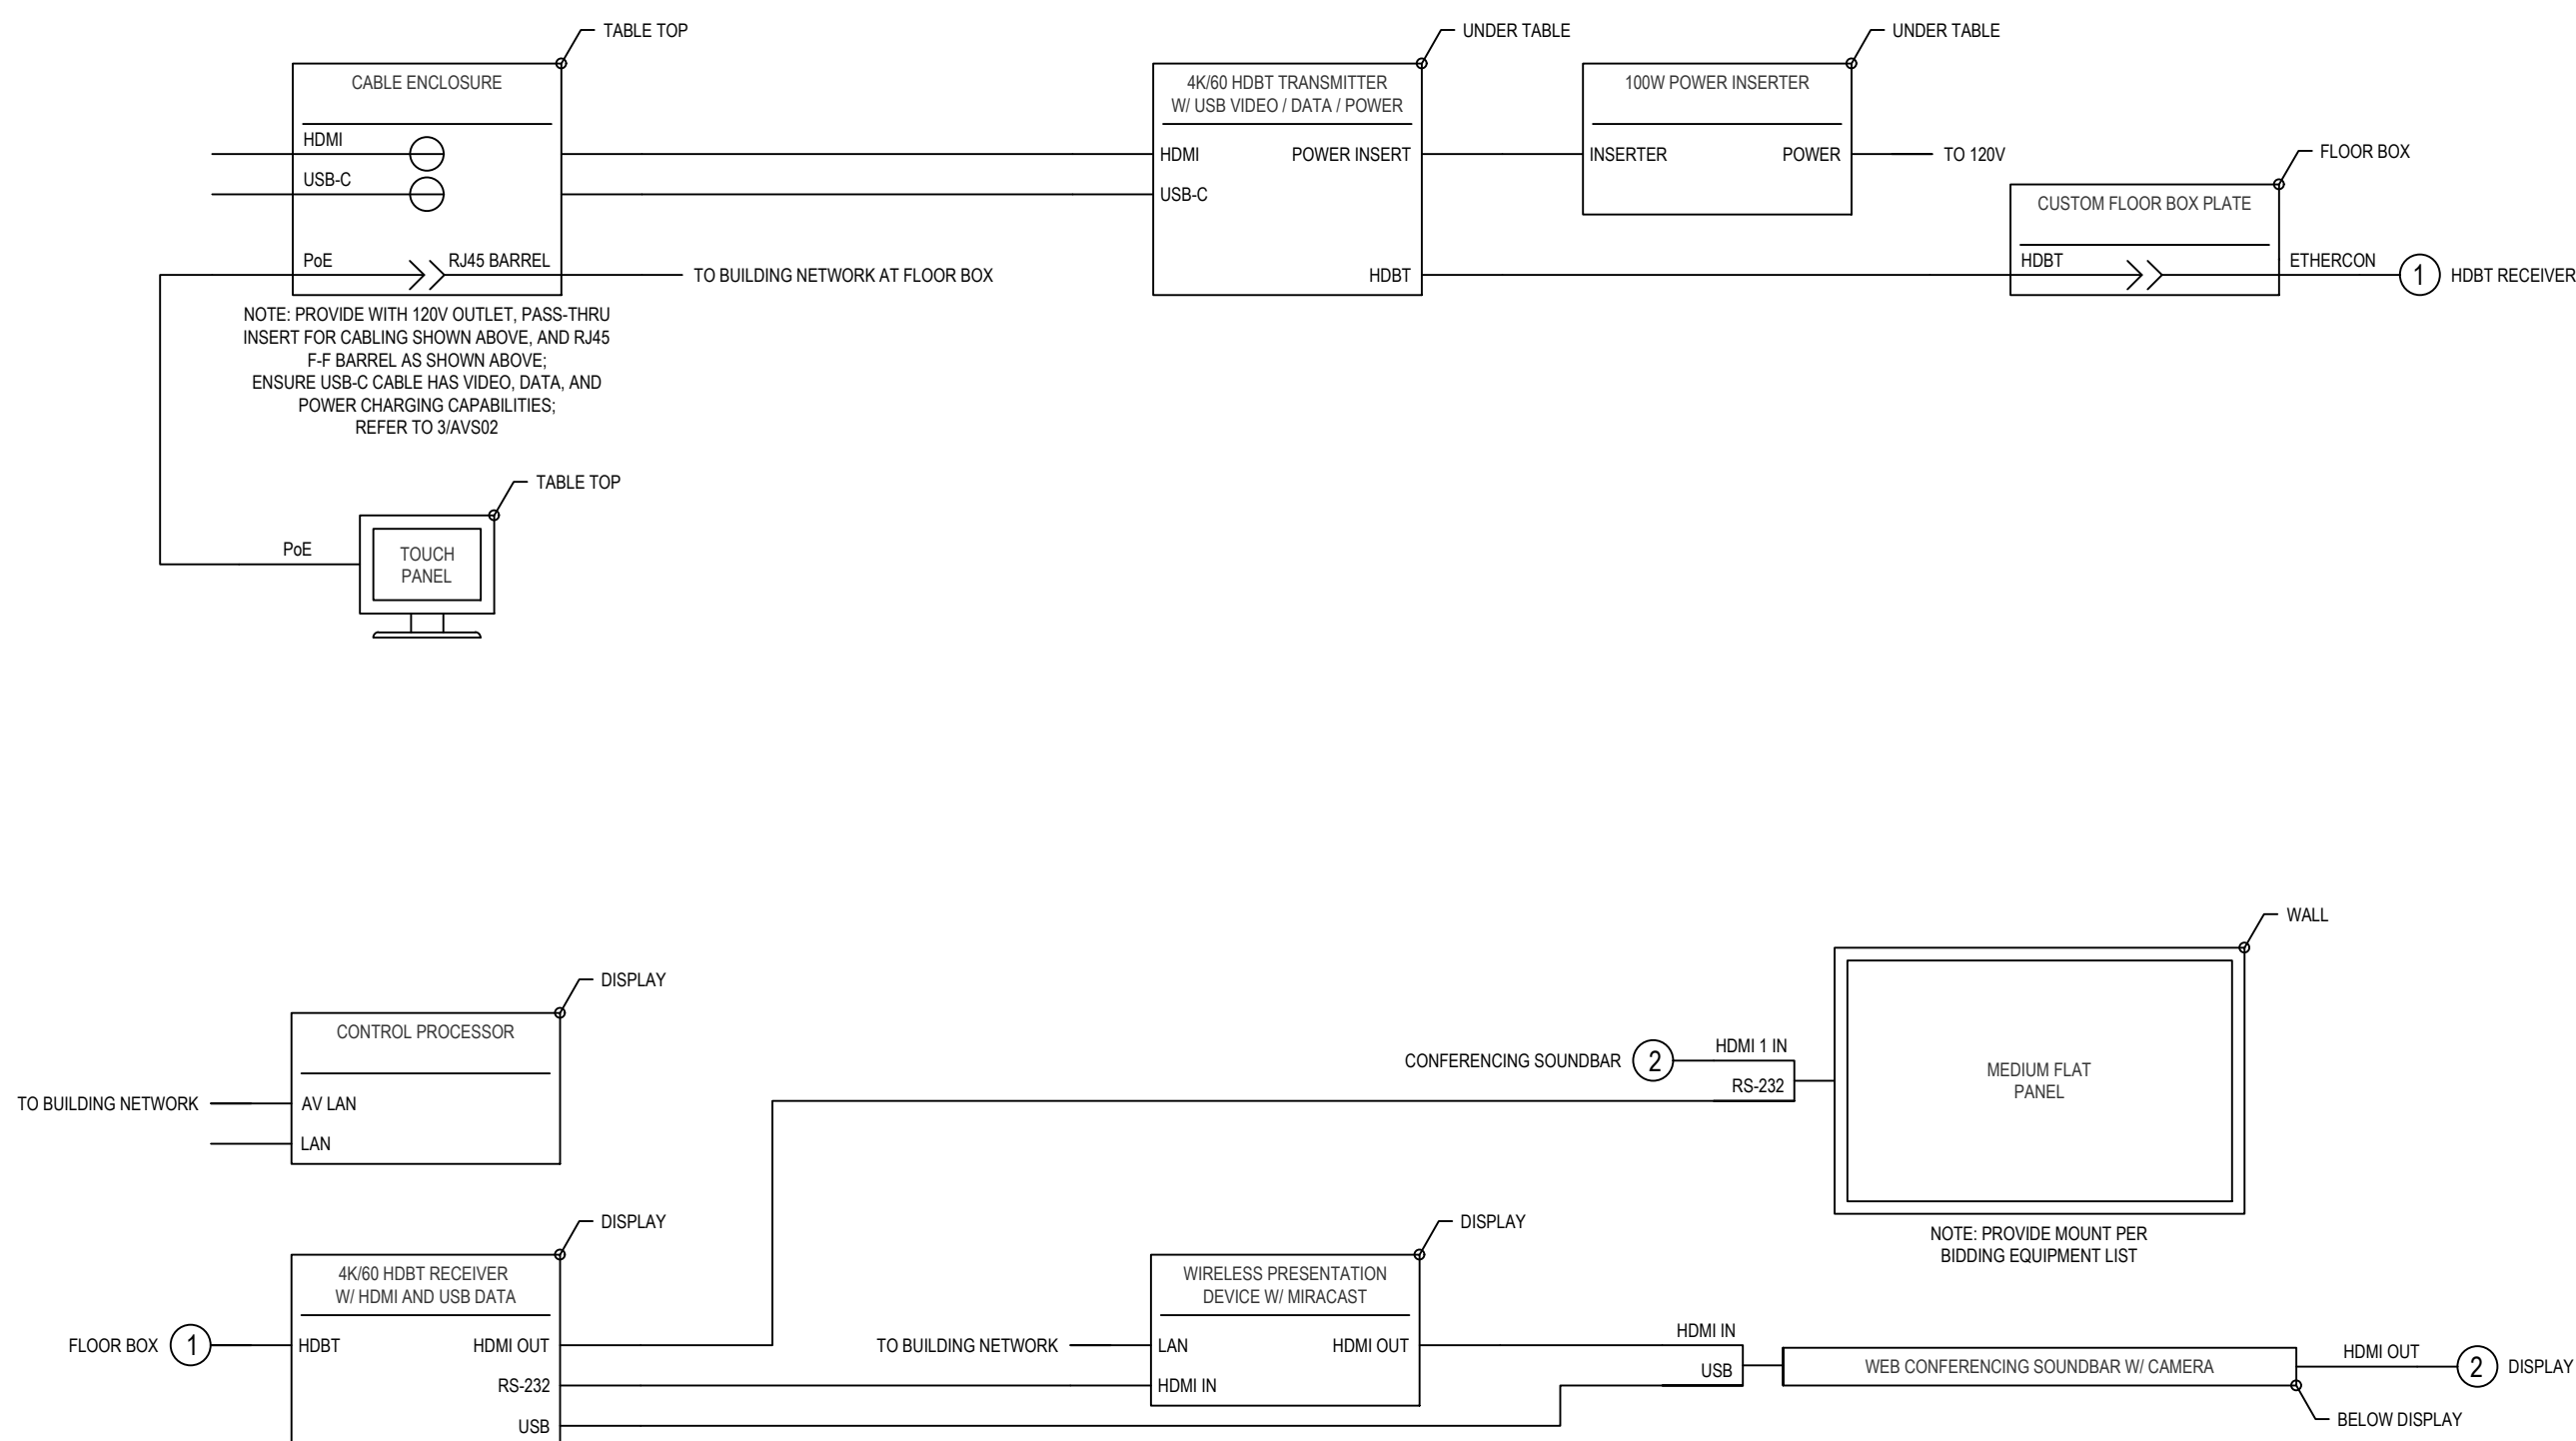

2
AVS02 SY03 - MEETING ROOM - QTY. 1 - ROOM NUMBER 118
SCALE: NTS

3
AVS02 CC01 - CABLE ENCLOSURE LAYOUT
SCALE: NTS



REVISIONS		
10/27/2026	A2	ADDENDUM 02

10/12/2026 BID AND PERMIT SET	
Drawn By	JF
Designer	NV5
Reviewer	NV5
Manager	CKRETOVIC

Hard copy is intended to be 24"x36" when plotted. Scale(s) indicated and graphic quality may not be accurate for any other size.

PROJECT NO.
2500281

SHEET NO.

AVS02

Van Buren Township

The Lake House

ADDENDUM 02

Bidding Equipment List

*See 274116 Appendices

ID	Manufacturer	Model	Item / Description	Unit Qty	Bidding Notes*
----	--------------	-------	--------------------	----------	----------------

Number : **169 / 170 / 164**

Type : **SY01**

Name : **Ballroom**

Rm Qty : **1**

Display Surfaces

1	Generic	Projection Screen	Projection Screen per Infrastructure Reference Drawings (OFOI)	2	B
---	---------	-------------------	--	---	---

Display Devices

2	Epson	EB-PU1008x	8,500 Lumens, 3LCD, Laser Light Projector, WUXGA w/ 4K Enhancement, Lens Not Included	2	D
3	Contractor Select	Zoom Lens	Projector Lens for Above	2	F
4	Chief	Projector Ceiling Mount	Contractor Selected Projector Ceiling Mount	2	-
5	Chief	Projector Mounting Hardware	Contractor Selected Projector Mounting Hardware as Needed	2	-
6	Contractor Select	Projector Extension Column	Projector Extension Column for Above	2	F
7	Samsung	QM55C	55" Professional LED Edge-Lit Display w/ Built-In Speakers, 3840 x 2160 Native	2	-
8	Chief	MFQUx	Medium Confidence Monitor Cart 2'	2	-

Source Devices

9	Extron	Sharelink Pro 2000 w/ Miracast	4K Wireless Presentation System w/ Miracast & ShareNext - US	2	-
10	BrightSign	XT244	4K H.265/H.264 Standard I/O Player	1	-

Video Capture, Streaming and Conferencing

11	Vaddio	RoboShot 20 UHD OneLink HDMI	UHD PTZ Camera - 12x Optical / 20x Digital Zoom - 74 Deg. FOV - HD-SDI/Network/HDBT/HDMI Outputs PoE++ - 2160p/30 Native	2	-
12	Extron	MediaPort 300	4K HDMI and Audio to USB Scaling Bridge	2	-

Signal Processing, Routing, and Distribution

13	Extron	DTP3 T 322 D	Two Input 4K/60 DTP3 Transmitter for HDMI and USB-C with Data – Decorator-Style Wallplate	2	D
14	Extron	DTP3 R 331	DTP3 Receiver for 4K/60 HDMI and USB Data	2	-
15	Extron	UPI 100	100 Watt Power Inserter for Extron USB-C Products	2	-
16	Extron	NAV E 501	1G Pro AV over IP Encoder - HDMI, Ethernet, and USB	2	H
17	Extron	NAV E 121	1G Pro AV over IP Compact Encoder - HDMI	7	-
18	Extron	NAV SD 121	1G Pro AV over IP Compact Scaling Decoder - HDMI	4	-
19	Extron	NAV SD 501	1G Pro AV over IP Scaling Decoder - HDMI, Ethernet, and USB	2	H
20	Extron	NAVigator	Pro AV over IP System Manager, 16 Endpoints	1	H
21	Netgear	M4250-40G8XF-PoE++	40 Port, 1G Ports, PoE++ (720/1650/2880W), (8) 10G SFP, 240 Gbps, AV Line Managed Network Switch	1	-

Van Buren Township

The Lake House

ADDENDUM 02

Bidding Equipment List

*See 274116 Appendices

ID	Manufacturer	Model	Item / Description	Unit Qty	Bidding Notes*
----	--------------	-------	--------------------	----------	----------------

Number : **169 / 170 / 164**

Type : **SY01**

Name : **Ballroom**

Rm Qty : **1**

Speech Reinforcement System/Audio Conferencing

22	Extron	DMP 128 Plus C AT	12x8 ProDSP Digital Matrix Audio Processor w/ USB Audio, Dante, and AEC	1	-
23	Shure	ULXD4Q	Quad Channel Digital Wireless Receiver	1	F
24	Contractor Select	Antenna Distribution	Contractor Select Antenna Distribution Systems	1	-
25	Shure	ULXD1	Wireless Bodypack Transmitter w/ On/Off Switch and LED Status, TQG Connector (Black Only)	2	F
26	Shure	WL185	Cardioid Lavalier Microphone	2	-
27	Shure	ULXD2/B58	Handheld Digital Wireless Microphone Transmitter w/ Beta 58 Cartridge	2	F
28	Shure	SB900C	Rechargeable Lithium-Ion Battery	4	-
29	Shure	SBRC-US	8-Bay Battery Rack Charger (SB900A)	1	-

Sound Reinforcement System

30	Extron	NETPA U 2004 FX	4-CH, 200W @ 70V/80hm/40hm Amplifier with Local and Dante Inputs, Integrated DSP	1	-
31	QSC	AD-C6T-xx	6" 2-Way Ceiling Speaker, Weather-Resistant, w/70V/100V transformer & 80hm Bypass	21	D
32	Listen Technologies	LW-170-02-09	Listen Everywhere 2 Channel Server, Dante	1	-
33	Listen Technologies	LA-480-01	16 Unit Docking / Charging Station	1	-
34	Listen Technologies	LA-438	Advanced Neck Loop (Adult)	2	-
35	Listen Technologies	LW-307	ListenWIFI Hearing Assistance Signage	1	-
36	Listen Technologies	LWR-1020	Listen EVERYWHERE Wi-Fi Audio Receiver 1020	7	-
37	Listen Technologies	LA-401	Universal Ear Speaker	7	-
38	Listen Technologies	LA-326	Universal Rack Mounting Kit	1	-

Control System

39	Extron	IPCP Pro 360Q xi	IP Link Pro Processor, Quad Core, (3) RS-232, (4) Relay, (4) I/O, Lan, (3) AV Lan Ports	1	-
40	Extron	TLP Pro 1035M	10.1" Wall Mount TouchLink Pro Touchpanel (Select Color)	2	D
41	Extron	TLP Pro 1035T	10.1" Tabletop TouchLink Pro Touchpanel (Select Color)	2	D
42	AV Contractor Select	Partition Sensor	Contractor Selected Partition Sensor	1	-

Van Buren Township

The Lake House

ADDENDUM 02

Bidding Equipment List

*See 274116 Appendices

ID	Manufacturer	Model	Item / Description	Unit Qty	Bidding Notes*
----	--------------	-------	--------------------	----------	----------------

Number : **169 / 170 / 164**

Type : **SY01**

Name : **Ballroom**

Rm Qty : **1**

Rack, Panels, Misc.					
43	Middle Atlantic	L2	Pre-Configured Lectern, 28" W x 25" D. With AV Connectivity and Flip Up Shelf	2	D
44	Middle Atlantic	BGR-4532-AV	BGR-Series 45RU, 32"D Equipment Rack Pre-Configured For AV	1	-
45	Middle Atlantic	PDX-920R-SP	NEXSYS 9 Outlet, 20 Amp Rackmount Power with Series Surge Protection	1	-
46	Middle Atlantic	PDT-1620C-NS	Vertical Power Distribution Strip, (16) Outlets, 20A	1	-
47	RCI Custom	NV5001-250217MM-02	Shared Credit Rack ID Panel with RJ45 Passthrough	1	-
48			Installation Materials as Defined in AV Systems Specification	Lot	
49			Custom Wall/Floor Box and Decorator-Style Plates as Needed	Lot	
50			Pre-Made Loose Cabling and Field Cabling as Needed	Lot	
51			Rack Panels, Vents, Mounts, Shelves, Other Rack Materials as Needed	Lot	
52			Rack ID Panels per Specification, See AV Rack Accessories	Lot	
53			Wall, Ceiling Mounts and Mounting Hardware as Needed	Lot	
54			Control System Accessories as Needed	Lot	
55			Power Supplies and Power Distribution as Needed	Lot	
56			Cable Terminations, Cable Dressing, Labels, Ties, Cable Management as Needed	Lot	

End of System

Van Buren Township

The Lake House

ADDENDUM 02

Bidding Equipment List

*See 274116 Appendices

ID	Manufacturer	Model	Item / Description	Unit Qty	Bidding Notes*
----	--------------	-------	--------------------	----------	----------------

Number : **104 / 105**

Type : **SY02**

Name : **Community Living Room / Multi-Purpose Room**

Rm Qty : **1**

Display Devices					
1	Samsung	QM98x	98" Professional LED Edge-Lit Display w/Built-In Speakers, 3840x2160 Native (Latest Model)	2	-
2	Chief	Wall Mount	Contractor Selected Flat Panel Display Wall Mount	2	-
3	Samsung	QM55C	55" Professional LED Edge-Lit Display w/ Built-In Speakers, 3840 x 2160 Native	1	-
4	Chief	AS3LDP7	Tempo™ Flat Panel Wall Mount System w/ PDU	1	-

Source Devices					
5	Extron	Sharelink Pro 2000 w/ Miracast	4K Wireless Presentation System w/ Miracast & ShareNext - US	3	-
6	Extron	Cable Cubby 202	Cable Enclosure, Flip Top, Basic, (1) AC & Cable Pass Through Bracket	1	-
7	Extron	Cable Enclosure Inserts	Inserts And Blank Plates For Above - Refer To System Diagram For Details	1	-
8	Extron	Cable Enclosure Accessories	Accessories For Above As Required (e.g. Cloaks, Brackets, Etc)	1	-

Video Capture, Streaming and Conferencing					
9	Vaddio	RoboShot 20 UHD OneLink HDMI	UHD PTZ Camera - 12x Optical / 20x Digital Zoom - 74 Deg. FOV - HD-SDI/Network/HDBT/HDMI Outputs PoE++ - 2160p/30 Native	2	-
10	Extron	MediaPort 300	4K HDMI and Audio to USB Scaling Bridge	1	-

Signal Processing, Routing, and Distribution					
11	Extron	NAV E 222	1G Pro AV Over IP Encoder with USB-C and HDMI	1	-
12	Extron	UPI 100	100 Watt Power Inserter for Extron USB-C Products	1	-
13	Extron	NAV E 121	1G Pro AV over IP Compact Encoder - HDMI	5	-
14	Extron	NAV SD 121	1G Pro AV over IP Compact Scaling Decoder - HDMI	3	-
15	Extron	NAV SD 501	1G Pro AV over IP Scaling Decoder - HDMI, Ethernet, and USB	1	H
16	Extron	NAV E 111 DTP3	1G Pro AV over IP Encoder with DTP3 Input	1	H
ADDENDU M 02.1	Extron	NAV E 111 DTP3	1G Pro AV over IP Encoder with DTP3 Input	(1)	H
17	Extron	DTP3 T 212 D	Two Input 4K/60 DTP3 Transmitter for USB-C and HDMI – Decorator-Style Wallplate, 18 Gbps	1	D
ADDENDU M 02.2	Extron	DTP3 T 212 D	Two Input 4K/60 DTP3 Transmitter for USB-C and HDMI – Decorator-Style Wallplate, 18 Gbps	(1)	D
18	Extron	NAVigator	Pro AV over IP System Manager, 16 Endpoints	1	H
19	Netgear	M4250-40G8XF-PoE++	40 Port, 1G Ports, PoE++ (720/1650/2880W), (8) 10G SFP, 240 Gbps, AV Line Managed Network Switch	1	-

Van Buren Township

The Lake House

ADDENDUM 02

Bidding Equipment List

*See 274116 Appendices

ID	Manufacturer	Model	Item / Description	Unit Qty	Bidding Notes*
----	--------------	-------	--------------------	----------	----------------

Number : **104 / 105**

Type : **SY02**

Name : **Community Living Room / Multi-Purpose Room**

Rm Qty : **1**

Speech Reinforcement System/Audio Conferencing					
20	Extron	DMP 64 Plus C AT	6x4 Digital Matrix Processor w/ AEC and Dante	1	-
21	Shure	MXA925x-R	Ceiling Array Microphone & Integrated Loudspeaker w/ Dante, PoE+, Round	2	D
22	Shure	ULXD4Q	Quad Channel Digital Wireless Receiver	1	F
23	Shure	ULXD1	Wireless Bodypack Transmitter w/ On/Off Switch and LED Status, TQG Connector (Black Only)	1	F
24	Shure	WL185	Cardioid Lavalier Microphone	1	-
25	Shure	ULXD2/B58	Handheld Digital Wireless Microphone Transmitter w/ Beta 58 Cartridge	1	F
26	Shure	SB900C	Rechargeable Lithium-Ion Battery	2	-
27	Shure	SBRC-US	8-Bay Battery Rack Charger (SB900A)	1	-

Van Buren Township

The Lake House

ADDENDUM 02

Bidding Equipment List

*See 274116 Appendices

ID	Manufacturer	Model	Item / Description	Unit Qty	Bidding Notes*
----	--------------	-------	--------------------	----------	----------------

Number : **104 / 105**

Type : **SY02**

Name : **Community Living Room / Multi-Purpose Room**

Rm Qty : **1**

Sound Reinforcement System					
28	Extron	NetPA U 1004-70V	4-CH, 100W @ 70V Amplifier with Local and Dante Inputs, Integrated DSP	1	-
29	QSC	AD-C6T-xx	6" 2-Way Ceiling Speaker, Weather-Resistant, w/70V/100V transformer & 8Ohm Bypass	16	D
30	Listen Technologies	LW-170-02-09	Listen Everywhere 2 Channel Server, Dante	1	-
31	Listen Technologies	LA-423	4-Port USB Charger For Use w/ Assisted Listening Receivers	1	-
32	Listen Technologies	LA-438	Advanced Neck Loop (Adult)	2	-
33	Listen Technologies	LW-307	ListenWIFI Hearing Assistance Signage	1	-
34	Listen Technologies	LWR-1020	Listen EVERYWHERE Wi-Fi Audio Receiver 1020	2	-
35	Listen Technologies	LA-401	Universal Ear Speaker	2	-
36	Listen Technologies	LA-326	Universal Rack Mounting Kit	1	-

Control System					
37	Extron	IPCP Pro 255Q xi	IP Link Pro Control Processor, Quad Core, (1) Bidirectional RS-232 Serial Port, (1) Bidirectional RS-232/RS-422/RS-485 Serial port, (1) IR/Serial Port, (4) Digital I/O ports, (2) Relays, Dual NIC	1	-
38	Extron	TLP Pro 1035M	10.1" Wall Mount TouchLink Pro Touchpanel (Select Color)	1	D
ADDENDU M 02.3	Extron	TLP Pro 1035M	10.1" Wall Mount TouchLink Pro Touchpanel (Select Color)	(1)	D
39	Extron	TLP Pro 1035T	10.1" Tabletop TouchLink Pro Touchpanel (Select Color)	1	D
40	AV Contractor Select	Partition Sensor	Contractor Selected Partition Sensor	1	-

Rack, Panels, Misc.					
ADDENDU M 02.4	Middle Atlantic	C5-FF27-2	C5-Series Frame, (2) Bay, 27"D	(1)	-
ADDENDU M 02.5	Middle Atlantic	C5-FF27-3	C5-Series Frame, (3) Bay, 27"D	1	-
ADDENDU M 02.6	Middle Atlantic	C5K2A1xxx	C5 Wood Kit 2-Bay 27"D 32"H	(1)	D
ADDENDU M 02.7	Middle Atlantic	C5K3A1xxx	C5 Wood Kit 3-Bay, 27" D x 32" H	1	-
41	Middle Atlantic	PDX-920R-SP	NEXSYS 9 Outlet, 20 Amp Rackmount Power with Series Surge Protection	2	-
42	RCI Custom	NV5001-250217MM-02	Shared Credit Rack ID Panel with RJ45 Passthrough	1	-
43			Installation Materials as Defined in AV Systems Specification	Lot	
44			Custom Wall/Floor Box and Decorator-Style Plates as Needed	Lot	
45			Pre-Made Loose Cabling and Field Cabling as Needed	Lot	
46			Rack Panels, Vents, Mounts, Shelves, Other Rack Materials as Needed	Lot	
47			Rack ID Panels per Specification, See AV Rack Accessories	Lot	
48			Wall, Ceiling Mounts and Mounting Hardware as Needed	Lot	
49			Control System Accessories as Needed	Lot	
50			Power Supplies and Power Distribution as Needed	Lot	
51			Cable Terminations, Cable Dressing, Labels, Ties, Cable Management as Needed	Lot	

End of System

Van Buren Township

The Lake House

ADDENDUM 02

Bidding Equipment List

*See 274116 Appendices

ID	Manufacturer	Model	Item / Description	Unit Qty	Bidding Notes*
----	--------------	-------	--------------------	----------	----------------

Number : **118**

Type : **SY03**

Name : **Meeting Room**

Rm Qty : **1**

Display Devices					
1	Samsung	QM65x	65" Professional LED Edge-Lit Display w/Built-In Speakers, 3840x2160 Native (Latest Model)	1	-
2	Chief	AS3LDP7	Tempo™ Flat Panel Wall Mount System w/ PDU	1	-

Source Devices					
3	Extron	Sharelink Pro 2000 w/ Miracast	4K Wireless Presentation System w/ Miracast & ShareNext - US	1	-
4	Extron	Cable Cubby 202	Cable Enclosure, Flip Top, Basic, (1) AC & Cable Pass Through Bracket	1	-
5	Extron	Cable Enclosure Inserts	Inserts And Blank Plates For Above - Refer To System Diagram For Details	1	-
6	Extron	Cable Enclosure Accessories	Accessories For Above As Required (e.g. Cloaks, Brackets, Etc)	1	-

Video Capture, Streaming and Conferencing					
7	Logitech	Rally Bar	All-In-One Video Bar w/ Camera, Speakers, and Beamforming Microphone	1	D

Signal Processing, Routing, and Distribution					
8	Extron	DTP3 T 321	4K/60 USB-C DTP3 Transmitter with Data and Power Delivery	1	-
9	Extron	DTP3 R 331	DTP3 Receiver for 4K/60 HDMI and USB Data	1	-
10	Extron	UPI 100	100 Watt Power Inserter for Extron USB-C Products	1	-

Control System					
11	Extron	IPCP Pro 255Q xi	IP Link Pro Control Processor, Quad Core, (1) Bidirectional RS-232 Serial Port, (1) Bidirectional RS-232/RS-422/RS-485 Serial port, (1) IR/Serial Port, (4) Digital I/O ports, (2) Relays, Dual NIC	1	-
12	Extron	TLP Pro 1035T	10.1" Tabletop TouchLink Pro Touchpanel (Select Color)	1	D

Rack, Panels, Misc.					
13			Installation Materials as Defined in AV Systems Specification	Lot	
14			Custom Wall/Floor Box and Decorator-Style Plates as Needed	Lot	
15			Pre-Made Loose Cabling and Field Cabling as Needed	Lot	
16			Rack Panels, Vents, Mounts, Shelves, Other Rack Materials as Needed	Lot	
17			Rack ID Panels per Specification, See AV Rack Accessories	Lot	
18			Wall, Ceiling Mounts and Mounting Hardware as Needed	Lot	
19			Control System Accessories as Needed	Lot	
20			Power Supplies and Power Distribution as Needed	Lot	
21			Cable Terminations, Cable Dressing, Labels, Ties, Cable Management as Needed	Lot	

End of System

Van Buren Township

The Lake House

ADDENDUM 02

Bidding Equipment List

*See 274116 Appendices

ID	Manufacturer	Model	Item / Description	Unit Qty	Bidding Notes*
----	--------------	-------	--------------------	----------	----------------

Number : **N/A**

Type : **SY04**

Name : **Outdoor Sound System**

Rm Qty : **1**

Source Devices					
1	Owner Furnished	DMP	Digital Media Player (OFCL)	1	A

Sound Reinforcement System					
2	Extron	NetPA U 2008 FX	8-Ch, Configurable Output Dante Amp, 200 watts,	1	-
3	QSC	AD-S8T-xx	8" Two-Way Wall-Mounted Speaker w/ 70V/100V Transformer & 8Ohm Bypass, Includes Mounting Hardware.	5	D
4	Contractor Select	Wall Mount	Contractor Selected Wall Mount For Above	5	-

Control System					
5	Extron	TLP Pro 835T	8" Tabletop TouchLink Pro Touchpanel (Select Color)	1	D

Rack, Panels, Misc.					
6			Installation Materials as Defined in AV Systems Specification	Lot	
7			Custom Wall/Floor Box and Decorator-Style Plates as Needed	Lot	
8			Pre-Made Loose Cabling and Field Cabling as Needed	Lot	
9			Rack Panels, Vents, Mounts, Shelves, Other Rack Materials as Needed	Lot	
10			Rack ID Panels per Specification, See AV Rack Accessories	Lot	
11			Wall, Ceiling Mounts and Mounting Hardware as Needed	Lot	
12			Control System Accessories as Needed	Lot	
13			Power Supplies and Power Distribution as Needed	Lot	
14			Cable Terminations, Cable Dressing, Labels, Ties, Cable Management as Needed	Lot	

End of System