

PLOT INFO: 10/2/2026 10:51:58 AM Autodesk Docs://2500281 - Van Buren Twp Lake House/2026_T_2500281.rvt

TECHNOLOGY ABBREVIATIONS		
GENERAL		
_____ A _____	IW	IMAGE WIDTH
&	J	JUNCTION
+18"	JB	JUNCTION BOX ABOVE FINISHED FLOOR OR FINISHED GRADE
@	KO	KNOCK OUT
AC	L	ALTERNATING CURRENT
ACT	LV	ACOUSTIC CEILING TILE LOW VOLTAGE
ADA	M	AMERICANS WITH DISABILITIES ACT
AFC	M, MIC	ABOVE FINISHED CEILING MICROPHONE
AFF	MAX	ABOVE FINISHED FLOOR MAXIMUM
AFG	MFR	ABOVE FINISHED GRADE MANUFACTURE
AHJ	MH	AUTHORITY HAVING JURISDICTION MANHOLE
ARCH	MIN	ARCHITECT OR ARCHITECTURAL MINIMUM
AV	MISC	AUDIOVISUAL MISCELLANEOUS
AVC	MTR	AUDIOVISUAL CONTRACTOR MOTOR
AWG	N	AMERICAN WIRE GAUGE
_____ B _____	NA	NOT APPLICABLE
B	NEC	BURIED NETWORK ELECTRONICS CONTRACTOR
BD	NEMA	BLACK DROP NATIONAL ELECTRICAL MANUFACTURERS ASSOCIATION
BET	NIC	BUILDING ENTRANCE TERMINAL NOT IN CONTRACT
BLDG	NTS	BUILDING NOT TO SCALE
BLKG	O	BLOCKING
_____ C _____	O	OWNER
C	OC	CONDUIT ON CENTER
CA	OFCI	CABLE OWNER FURNISHED - CONTRACTOR INSTALLED
CAB	OFOI	CABINET OWNER FURNISHED OTHER INSTALLED
CAT	OH	CATALOG OVERHEAD
CATV	P	CABLE TELEVISION
CCTV	PLYWD	CLOSED CIRCUIT TELEVISION PLYWOOD
CD	O	CASE DEPTH
CH	QTY	CASE HEIGHT QUANTITY
CL	R	CENTER LINE
CLG	RCP	CEILING REFLECTED CEILING PLAN
CR	REF	CREDENZA REFER / REFERENCE
CW	REQ'D	CASE WIDTH REQUIRED
_____ D _____	RGS	DRAWING RIGID GALVANIZED STEEL
DWG	RHAFF	E BOTTOM OF ROLLER HOUSING ABOVE FINISHED FLOOR
_____ E _____	RM	ROOM
EC	S	ELECTRICAL CONTRACTOR
EMT	SCC	ELECTRIC METALLIC TUBING STRUCTURED CABLE CONTRACTOR
EQUIP	T	EQUIPMENT
EST	TYP	ESTIMATE TYPICAL
EXIST, (E)	U	EXISTING
_____ F _____	UG	FIRE ALARM CONTROL PANEL UNDERGROUND
FACP	UNO	FIRE ALARM CONTROL PANEL UNLESS NOTED OTHERWISE
FACP	UPS	FIRE ALARM CONTROL PANEL UNINTERRUPTIBLE POWER SUPPLY
FCU	UTP	FAN COIL UNIT UNSHIELDED TWISTED-PAIR
FPD	V	FLAT PANEL DISPLAY
_____ G _____	VIF	GENERAL CONTRATOR VERIFY IN FIELD
GC	W	GENERAL CONTRATOR WITH
_____ H _____	W/O	HANDHOLE WITHOUT
_____ I _____	WP	IMAGE HEIGHT WATERPROOF(ING)
IH	X	BOTTOM OF IMAGE HEIGHT ABOVE FINISHED FLOOR
IHAF	XP	INPUT/OUTPUT EXPLOSION PROOF
IO		

TECHNOLOGY SPECIFIC			
J#	AV JUNCTION BOX	F#(P#)	FLOOR BOX W/ AV AND POWER
N#	TELECOM JUNCTION BOX	F#(N# P#)	FLOOR BOX W/ AV, TELECOM AND POWER
P#	POWER OUTLET	PT#	FLOOR POKE-THRU DEVICE
J#(N#)	JUNCTION BOX W/ AV AND TELECOM	PT#(N#)	FLOOR POKE-THRU DEVICE W/ TELECOM
J#(P#)	JUNCTION BOX W/ AV AND POWER	PT#(P#)	FLOOR POKE-THRU DEVICE W/ AV AND POWER
J#(N# P#)	JUNCTION BOX W/ AV, TELECOM AND POWER	PT#(N# P#)	FLOOR POKE-THRU DEVICE W/ AV, TELECOM AND POWER
F#	FLOOR BOX	FS#	FLOOR CONDUIT STUB
F#(N#)	FLOOR BOX W/ TELECOM		
(JUNCTION BOX "J#" LETTER CODE MAY VARY BY BOX JUNCTION)			

TECHNOLOGY SYMBOLS LEGEND				(THIS IS A MASTER LEGEND, NOT ALL SYMBOLS MAY APPEAR ON DRAWINGS.)			
GENERAL		TECHNOLOGY DEVICES		TECHNOLOGY DEVICES		TELECOM BUILDING RISER	
SYMBOL	DESCRIPTION	SYMBOL	DESCRIPTION	SYMBOL	DESCRIPTION	SYMBOL	DESCRIPTION
	NEW WORK		FLOOR BOX / FLOOR POKE-THRU DEVICE / FLOOR CONDUIT STUB		ACCESS PANEL		48 - PORT COPPER PATCH PANEL, RACK MOUNT
	EXISTING WORK TO REMAIN		WALL JUNCTION BOX		LARGE JUNCTION BOX		48 - PORT OPTICAL FIBER PANEL, RACK MOUNT
	EXISTING WORK TO BE REMOVED (DEMO)		CEILING JUNCTION BOX		CABLE BASKET - REFER TO PLANS FOR SIZE		110 - STYLE PUNCHDOWN BLOCK, WALL MOUNT
	BELOW FLOOR OR GRADE		FLOOR TELECOM OUTLET		CABLE RUNWAY - REFER TO PLANS FOR SIZE		TELECOM MAIN GROUNDING BUSBAR (TMGB), WALL MOUNT
	CONDUIT RISER - DETAIL # / SHEET #		WALL TELECOM OUTLET		TELECOM GROUNDING BUSBAR (TGB), WALL MOUNT		PRIMARY CABLE PROTECTION, WALL MOUNT
	CALLOUT SYMBOL - DETAIL # / SHEET #		CEILING TELECOM OUTLET		CATV HEAD END EQUIPMENT		CATV TAP
	ELEVATION SYMBOL - DETAIL # / SHEET #		FLOOR POWER CIRCUIT		CONDUIT - REFER TO PLANS FOR QUANTITY & SIZE		CONDUIT - REFER TO PLANS FOR SIZE
	SECTION SYMBOL - DETAIL # / SHEET #		FLOOR POWER DUPLEX RECEPTACLE		J-HOOK - REFER TO SPECIFICATIONS FOR DETAILS		
TECHNOLOGY TAG DESIGNATIONS			FLOOR POWER DOUBLE DUPLEX RECEPTACLE		CONDUIT - RESERVED FOR FIBER BACKBONE	ERRCS - DAS	
DISPLAY TYPE			CONDUIT - RESERVED FOR COPPER BACKBONE		CONDUIT - RESERVED FOR HORIZONTAL CABLING		DESCRIPTION
NUMBER DESIGNATES THE DISPLAY TYPE			CONDUIT - RESERVED FOR FUTURE		CONDUIT - RESERVED FOR SECURITY		DESCRIPTION
(REFER TO THE DISPLAY TYPE LEGEND FOR MORE INFORMATION)			WALL POWER CIRCUIT				DESCRIPTION
PROJECTION TYPE			WALL POWER DUPLEX RECEPTACLE				DESCRIPTION
LETTER DESIGNATES THE PROJECTION SCREEN TYPE			WALL POWER DOUBLE DUPLEX RECEPTACLE		FIRE RATED ASSEMBLY		DESCRIPTION
(REFER TO THE PROJECTION SCREEN TYPE LEGEND FOR MORE INFORMATION)			CEILING POWER CIRCUIT		BUILDING ENTRANCE TERMINAL		DESCRIPTION
TELECOM DESIGNATORS			CEILING DUPLEX RECEPTACLE		CATV TAP		DESCRIPTION
N-NUMBER DESIGNATES BOX-TYPE & MOUNTING STYLE			CEILING DOUBLE DUPLEX RECEPTACLE		GROUNDING BUSBAR		DESCRIPTION
(REFER TO THE TELECOM CABLING LEGEND FOR MORE INFORMATION)			CEILING LOUDSPEAKER BY AV CONTRACTOR - SHOWN FOR COORDINATION PURPOSES ONLY. EXACT LOCATION TO BE COORDINATED BY THE AV CONTRACTOR. SUBSCRIPT NUMBER DESIGNATES THE SPEAKER ZONE.		MAIN GROUNDING BUSBAR		DESCRIPTION
VERTICAL PLACEMENT			CEILING AV CAMERA BY AV CONTRACTOR - SHOWN FOR COORDINATION PURPOSES ONLY. EXACT LOCATION TO BE COORDINATED BY THE AV CONTRACTOR.		ELECTRICAL / SECURITY PANEL		DESCRIPTION
J# J# OR J#(N#) OR N#(N#)			CEILING AV MICROPHONE BY AV CONTRACTOR - SHOWN FOR COORDINATION PURPOSES ONLY. EXACT LOCATION TO BE COORDINATED BY THE AV CONTRACTOR.		TERMINATION BLOCK - 66 STYLE		DESCRIPTION
(DENOTES DEVICES WHICH FALL ON THE SAME VERTICAL PLANE)			FLAT PANEL DISPLAY BY AV CONTRACTOR - SHOWN FOR COORDINATION PURPOSES ONLY. REFER TO DETAIL SHEETS FOR MORE INFORMATION.		TERMINATION BLOCK - 110 STYLE		DESCRIPTION
			PROJECTOR BY AV CONTRACTOR - SHOWN FOR COORDINATION PURPOSES ONLY. REFER TO DETAIL SHEETS FOR MORE INFORMATION.		VERTICAL CABLE MANAGER		DESCRIPTION
			PROJECTION SCREEN - REFER TO THE PROJECTION SCREEN TYPE LEGEND AND NOTES FOR MORE INFORMATION.		RACK - 2 POST		DESCRIPTION
			EQUIPMENT RACK		RACK - 4 POST		DESCRIPTION
			PLYWOOD BACKBOARD				DESCRIPTION

TECHNOLOGY GENERAL NOTES

DRAWINGS: NOTIFY THE DESIGNER OF ANY DISCREPANCIES BETWEEN THESE CONTRACT DRAWINGS AND FIELD CONDITIONS.	FIRE STOPPING: THE FIRE STOP SYSTEM SHALL COMPLY WITH THE IBC, NEC AND WITH NFPA 101-LIFE SAFETY CODE (LATEST EDITION) AND SHALL BE MADE AVAILABLE FOR INSPECTION BY THE LOCAL INSPECTION AUTHORITIES PRIOR TO CABLE SYSTEM ACCEPTANCE. THE CONTRACTOR SHALL BE RESPONSIBLE FOR VERIFYING THE FIRE RATING OF ALL WALLS AND FLOORS HAVING PENETRATIONS. COORDINATE SEALANT INSTALLATION WITH WORK OF OTHER TRADES. REFER TO GENERAL AND / OR ELECTRICAL SPECIFICATION SECTIONS FOR FURTHER MATERIAL AND INSTALLATION PARAMETERS.	AIR CONDITIONING EQUIPMENT, MOTORS, HEAVY INDUSTRIAL EQUIPMENT, OR DIMMED LIGHTING LOADS; ALL OF WHICH CREATE TRANSIENTS, HARMONICS, SURGES AND SPIKES. FOR ADDITIONAL GUIDELINES REFER TO THE IEEE STD. 1100 (2005) EMERALD BOOK 'RECOMMENDED PRACTICE FOR POWERING AND GROUNDING ELECTRONIC EQUIPMENT'. WHERE PRACTICAL, ALL TECHNICAL POWER CIRCUITS FOR EQUIPMENT WITHIN A ROOM SHOULD BE ON THE SAME PHASE TO ENSURE PROPER EQUIPMENT TIMING WITHIN THE SYSTEM. TRANSIENT VOLTAGE SURGE SUPPRESSION (TVSS) DEVICES SHOULD BE PROVIDED AT POWER DISTRIBUTION PANELS SERVING TECHNICAL POWER CIRCUITS. THESE TVSS DEVICES MUST BE INSTALLED ACCORDING TO NEC ARTICLE 285. ALL DEVICES MUST BE UL 1449 COMPLIANT. IN BROADCAST APPLICATIONS OR IN LARGE SYSTEMS, A SEPARATELY DERIVED TECHNICAL POWER SOURCE PROVIDED BY AN ELECTROSTATIC SHIELDED ISOLATION TRANSFORMER MAY BE REQUIRED.
INSTALLATION: INSTALL ALL COMPONENTS AS PER MANUFACTURERS RECOMMENDATIONS AND PER ALL APPLICABLE CODES.	EMERGENCY COMMUNICATIONS: CONTRACTOR TO VERIFY ALL CODE AND TELECOMMUNICATIONS REQUIREMENTS FOR AEDS, EMERGENCY PHONES, AND AREA OF REFUGE SYSTEMS AND SIGNAGE PER THE AHJ. REFERENCE ARCHITECTURAL DRAWINGS FOR EMERGENCY COMMUNICATIONS SIGNAGE AND ELECTRICAL AND FIRE PROTECTION DRAWINGS FOR EMERGENCY COMMUNICATIONS REQUIREMENTS.	ALL TECHNICAL POWER OUTLETS MUST BE WIRED AS "ALWAYS ON". NO OUTLETS SERVING TECHNOLOGY SYSTEMS SHALL BE ON SWITCHED, TIME OF DAY, OR OCCUPANCY CONTROLLED OUTLETS.
SUBSTITUTIONS: THE MAKE AND MODEL OF LOW VOLTAGE INFRASTRUCTURE DEVICES IN THE TECHNOLOGY LEGENDS HAVE BEEN LISTED TO ESTABLISH THE DESIRED LEVEL OF QUALITY AND PERFORMANCE FOR EACH DEVICE. UNLESS OTHERWISE INDICATED, THE INSTALLING CONTRACTOR MAY SUBSTITUTE THESE DEVICES WITH EQUIVALENT APPROVED PRODUCT BY OTHER MANUFACTURERS.	GROUNDING: GROUND COMMUNICATIONS SYSTEMS AND EQUIPMENT IN ACCORDANCE WITH THE ANSI/TIA-607-(LATEST EDITION) GROUNDING STANDARD AND APPLICABLE NEC REQUIREMENTS EXCEPT WHERE THE DRAWINGS OR SPECIFICATIONS EXCEED NEC REQUIREMENTS. ALL RACKS, METALLIC BACKBOARDS, CABLE SHEATHS, METALLIC STRENGTH MEMBERS, SPLICE CASES, CABLE TRAYS, ETC. ENTERING OR RESIDING IN TECHNICAL EQUIPMENT SPACES SHALL BE GROUNDED TO THEIR RESPECTIVE GROUND SYSTEM USING A MINIMUM #6 AWG STRANDED COPPER BONDING CONDUCTOR AND COMPRESSION CONNECTORS. ALL WIRES USED FOR TECHNICAL POWER SYSTEMS GROUNDING PURPOSES SHALL BE IDENTIFIED WITH GREEN INSULATION OR IDENTIFIED AT EACH TERMINATION POINT WITH A WRAP OF GREEN TAPE. ALL CABLES AND BUS BARS SHALL BE IDENTIFIED AND LABELED "TECHNICAL POWER SYSTEM GROUND".	TECHNICAL GROUND SYSTEM (TGS) TECHNICAL GROUND SHALL CONSIST OF AN INSULATED GROUND CONDUCTOR FROM THE PANEL BOARD TO EACH TECHNICAL GROUND RECEPTACLE. AT THE RECEPTACLE, THE GROUND CONDUCTOR SHALL BE ELECTRICALLY ISOLATED FROM THE ELECTRICAL BOX AND CONDUIT SYSTEM.
DEVICE MOUNTING: DEVICE SPECIFIED MOUNTING ELEVATIONS ARE "ON CENTER" UNLESS OTHERWISE NOTED. ALL DEVICE HEIGHTS SHALL COMPLY WITH ANSI 117.1 CHAPTER 3, SECTION 307, PROTRUDING OBJECTS AND CHAPTER 3, SECTION 308, REACH RANGES. IF ANY DEVICE OR BOX SPECIFIED WITHIN IS FOUND TO BE IN CONFLICT WITH ABOVE SECTIONS A CONFIRMING RFI SHOULD BE PLACED PRIOR TO LOCATING.	TECHNICAL POWER & GROUNDING SYSTEM: DUE TO THE SENSITIVE NATURE OF ELECTRONIC EQUIPMENT THAT IS BEING USED, POWER QUALITY MUST BE ASSURED. POWER FOR TECHNOLOGY SYSTEMS SHOULD BE DERIVED FROM DEDICATED TECHNICAL POWER PANELS WHICH DO NOT SHARE CIRCUITS WITH EQUIPMENT LOADS THAT GENERATE ELECTRICAL NOISE ON THE POWER LINE. THIS MIGHT INCLUDE:	TECHNICAL ELECTRICAL SUPPLY GROUNDING SHALL BE VIA A GROUNDING ELECTRODE AND MEET NEC ARTICLE 250 REQUIREMENTS. A TECHNICAL POWER SYSTEM IS FURTHER DEFINED IN NEC ARTICLE 640 AS "AN ELECTRICAL DISTRIBUTION SYSTEM WITH GROUNDING IN ACCORDANCE WITH 250.146(D), WHERE THE EQUIPMENT GROUNDING CONDUCTOR IS ISOLATED FROM THE PREMISES GROUNDING CONDUCTOR EXCEPT AT A SINGLE GROUNDED TERMINATION POINT WITHIN A BRANCH-CIRCUIT PANEL BOARD, AT THE ORIGINATING (MAIN BREAKER) BRANCH-CIRCUIT PANEL BOARD, OR AT THE PREMISES GROUNDING ELECTRODE".
FLOOR BOX, JUNCTION BOX, AND PULL BOX COVERS: UNLESS OTHERWISE DIRECTED, ALL FLOOR BOXES, JUNCTION BOXES, AND PULL BOXES MUST BE PROVIDED WITH A COVER. WHERE SINGLE OR MULTI-DEVICE RAISED DEVICE COVERS ARE SPECIFIED IN THE SCHEDULE, MATCH THE RAISED COVER DEPTH TO THE WALL THICKNESS. PROVIDE ALL FLOOR BOXES, JUNCTION BOXES, AND PULL BOXES WITH APPROPRIATE KNOCKOUTS TO MATCH CONDUIT REQUIREMENTS. WHERE JUNCTION BOXES AND PULL BOXES ARE MOUNTED AT OR ABOVE FINISHED CEILING HEIGHT, INSTALL BOXES WITH OPEN SIDE FACING DOWN.		INSULATED GROUNDING CONDUCTORS FROM THE BREAKER PANEL BOARDS SHALL BE IN A "STAR" CONFIGURATION AND NOT LOOP FROM ONE PANEL TO THE NEXT PANEL. AT EACH BREAKER PANEL, PROVIDE AN INSULATED GROUND BUS BAR FOR CONNECTIONS OF ALL TGS INSULATED GROUND CONDUCTORS AND NO OTHERS. THE GREEN SAFETY GROUND WIRES FROM EACH TGS RECEPTACLE OR CIRCUIT ARE BROUGHT TO THIS BUS. EACH TECHNICAL POWER RECEPTACLE SHALL BE OF A UNIQUE COLOR AND / OR CLEARLY AND PERMANENTLY LABELED "TECHNICAL POWER".

CONTRACTOR RESPONSIBILITY MATRIX

ALL ITEMS AND TASKS LISTED ARE THE RESPONSIBILITY OF THE NOTED CONTRACTOR			
#	ITEM / TASK	FURNISH	INSTALL
1	UNISTRUT, THREADED ROD, SUPPORT CABLE, FASTENERS OR OTHER HARDWARE REQUIRED TO ATTACH AUDIOVISUAL WALL OR CEILING MOUNTS TO STRUCTURE	GC	GC
2	ROUGH OR FINISHED TRIM, CASEWORK AND MILLWORK	GC	GC
3	STRUCTURAL BACKING ("BLOCKING") AS REQUIRED TO SUPPORT WALL MOUNTED AUDIOVISUAL COMPONENTS AND STRUCTURAL WORK FOR SPECIAL CONSTRUCTION	GC	GC
4	AC POWER SYSTEMS, CONDUIT, RACEWAYS, ELECTRICAL BACK BOXES, JUNCTION BOXES, PULL BOXES, FLOOR BOXES AND OTHER INFRASTRUCTURE	GC	GC
5	LIGHTING FIXTURES, DIMMING SYSTEMS AND WALL CONTROLLERS	GC	GC
6	LOW VOLTAGE AV CONTROL INTERFACE FOR LIGHTING SYSTEM (DIMMER SIDE) AND PATHWAY TO AUDIOVISUAL CONTROL SYSTEM EQUIPMENT RACK	GC	GC
7	LOW VOLTAGE AV CONTROL INTERFACE FOR MOTORIZED WINDOW SHADES AND PATHWAY TO AUDIOVISUAL CONTROL SYSTEM EQUIPMENT RACK	GC	GC
8	TELECOMMUNICATIONS STRUCTURED CABLING SYSTEMS, HORIZONTAL AND BACKBONE CABLING AND TERMINATION, ASSOCIATED CABINETS, RACKS, RACEWAYS AND CABLE MANAGEMENT SYSTEMS	SCC	SCC
9	TELECOMMUNICATIONS CONNECTOR INSERT PLATES FOR FLOOR BOXES AND / OR WALL BOXES	SCC	SCC
10	PROJECTION SCREENS - WALL MOUNTED, CEILING MOUNTED, OR FIXED FRAME	GC	GC
11	AUDIOVISUAL CONNECTOR INSERT PLATES FOR FLOOR BOXES AND / OR WALL BOXES	AVC	AVC
12	AUDIOVISUAL CABLING AND TERMINATIONS FOR AUDIOVISUAL SYSTEMS	AVC	AVC
13	PROJECTORS, FLAT PANEL DISPLAYS, CONTROL PANELS, MICROPHONES, SPEAKERS AND OTHER AUDIOVISUAL EQUIPMENT	AVC	AVC
14	MOTORIZED PROJECTOR LIFTS	GC	GC
15	LECTERNS / SPECIALTY TECHNICAL FURNITURE	AVC	AVC
16	AUDIOVISUAL EQUIPMENT RACKS	AVC	AVC
17	ELECTRONIC SECURITY SYSTEMS EQUIPMENT AND SECURITY CABLING FOR ACCESS CONTROL, INTRUSION ALARM, DURESS, AND OTHERS AS SPECIFIED	SC	SC
18	WIRELESS ACCESS POINT ENCLOSURE BACKBOX	GC	GC
19	WIRELESS ACCESS POINT ENCLOSURES	SCC	SCC
20	WIRELESS ACCESS POINT DEVICES	O	SCC
21	NETWORK SWITCHES AND EQUIPMENT	O	O
22	EMERGENCY PHONES	SC	SC
23	EQUIPMENT PATCH CORDS - (IF EQUIPMENT ROOM PATCH CORDS ARE INSTALLED BY SCC THEN THEY SHALL BE RESPONSIBLE FOR COORDINATING AND CONFIGURING PACTHING TO NETWORK SWITCHES WITH OWNER)	SCC	SCC
24	STATION PATCH CORDS	SCC	SCC
25	FIBER PATCH CORDS	O	O
26	RACK MOUNTED UPS	O	O

TECHNOLOGY RISER GENERAL NOTES

RISER DRAWINGS AND CONDUIT ROUTING THE ROOM RISER DRAWINGS ARE DIAGRAMMATIC IN NATURE. CONDUIT PATHS SHOWN ON THE ROOM RISERS ARE INTENDED TO CONVEY REQUIRED DEVICE INTERCONNECTION AND SIZES ONLY. ACTUAL CONDUIT ROUTING IN THE FIELD MAY BE REQUIRED TO FOLLOW ROUTING CONTRARY TO THAT IMPLIED BY THE ROOM RISER. CONDUIT ROUTING IS AT CONTRACTOR'S DISCRETION, BUT THE CONTRACTOR SHALL PROVIDE A PULL BOX IMMEDIATELY BEFORE AND AFTER ANY CONDUIT RUN SECTION CONTAINING TWO NINETY-DEGREE TURNS, OR ANY SINGLE RUN EXCEEDING FIFTY FEET IN LENGTH REGARDLESS OF WHETHER PULL BOXES ARE SHOWN ON THE DRAWINGS OR NOT. IN ALL CASES, CONDUIT ROUTES SHALL FOLLOW THE SHORTEST PATH POSSIBLE WHILE COMPLYING WITH INDUSTRY STANDARDS AND BEST PRACTICES.	POWER DESIGNATORS AND RECEPTACLES POWER DESIGNATORS AND RECEPTACLES WHICH APPEAR ON THE ROOM RISER DRAWINGS ARE SHOWN TO INDICATE THEIR ASSOCIATION WITH AND REQUIRED ADJACENCY TO AUDIOVISUAL COMPONENTS. NOTE THAT NOT ALL POWER RECEPTACLES REQUIRED TO SUPPORT THE AUDIOVISUAL SYSTEMS ARE SHOWN ON THE ROOM RISER DIAGRAMS; ONLY THOSE THAT ARE PART OF OR INTERFACE WITH THE AUDIOVISUAL JUNCTION BOXES ARE SHOWN. REFER TO THE AUDIOVISUAL INFRASTRUCTURE PLANS, ELEVATIONS AND DETAILS FOR ADDITIONAL GUIDANCE REGARDING AUDIOVISUAL POWER LOCATIONS. REFER TO THE ELECTRICAL DRAWINGS FOR COMPLETE POWER LAYOUTS AND CIRCUITING DETAILS.
CONDUIT RUNS: ALL CONDUIT RUNS SHALL BE STEEL, THIN-WALL ELECTRICAL METALLIC TUBING (EMT) UNLESS OTHERWISE INDICATED. THE USE OF FLEXIBLE CONDUIT IS NOT PERMISSIBLE EXCEPT WHERE INDICATED ON THE DRAWINGS. CONDUIT SIZES AND INTERCONNECTIONS SHALL BE AS INDICATED ON THE DRAWINGS.	TELECOM OUTLETS JUNCTION BOXES FOR TELECOM OUTLETS WHICH APPEAR ON THE ROOM RISER DRAWINGS ARE SHOWN TO INDICATE THEIR ASSOCIATION WITH AND REQUIRED ADJACENCY TO AUDIOVISUAL COMPONENTS.
CONDUIT STUBS TERMINATE CONDUIT STUBS INTO CLEAR SPACE 18 INCHES ABOVE ACCESSIBLE CEILING IN ROOM INDICATED.	AV SPECIFIC ROOM RISERS NOT ALL TELECOM OUTLETS REQUIRED TO SUPPORT THE AUDIOVISUAL SYSTEMS ARE SHOWN ON THE ROOM RISER DIAGRAMS; ONLY THOSE THAT ARE PART OF OR INTERFACE WITH AUDIOVISUAL JUNCTION BOXES ARE SHOWN. REFER TO THE AUDIOVISUAL INFRASTRUCTURE PLANS, ELEVATIONS AND DETAILS FOR ADDITIONAL GUIDANCE REGARDING AUDIOVISUAL TELECOM OUTLET LOCATIONS. REFER TO THE STRUCTURED CABLING DRAWINGS FOR COMPLETE TELECOMMUNICATIONS PATHWAYS, OUTLETS AND CABLING REQUIREMENTS.
NYLON BUSHINGS PROVIDE A NYLON BUSHING ON ALL CONDUIT STUBS AND NON-TERMINATING CONDUIT ENDS TO PROTECT WIRE PULLS.	CONDUITS SHOWN ON THE ROOM RISER DRAWINGS ARE FOR AV ONLY AND SHALL NOT BE USED FOR TELECOM CABLES.
PULL STRINGS ALL CONDUIT RUNS SHALL BE PROVIDED WITH A #12 PULL STRING OR EQUAL.	

TECHNOLOGY SHEET INDEX

ISSUE				SHEET NUMBER	SHEET DESCRIPTION
2026-10-12 BID AND PERMIT SET	2026-09-21 CD PEER REVIEW	2026-09-09 CD TEAM REVIEW	2026-08-10 CD 50% PROGRESS		
•	•	•	•	T001	TECHNOLOGY INFRASTRUCTURE GENERAL NOTES, LEGENDS, ABBREVIATIONS, AND SHEET INDEX.
•	•	•	•	T002	TECHNOLOGY INFRASTRUCTURE LEGENDS AND NOTES
•	•	•	•	T003	TECHNOLOGY INFRASTRUCTURE LEGENDS AND SCHEDULES
•	•	•	•	T100	TELECOM SITE PLAN
•	•	•	•	T101A	TECHNOLOGY INFRASTRUCTURE PLAN - FLOOR AREA A
•	•	•	•	T101B	TECHNOLOGY INFRASTRUCTURE PLAN - FLOOR AREA B
•	•	•	•	T201A	TECHNOLOGY INFRASTRUCTURE REFLECTED CEILING PLAN - FLOOR AREA A
•	•	•	•	T201B	TECHNOLOGY INFRASTRUCTURE REFLECTED CEILING PLAN - FLOOR AREA B
•	•	•	•	T301A	TELECOM PLAN - FLOOR AREA A
•	•	•	•	T301B	TELECOM PLAN - FLOOR AREA B
•	•	•	•	T401	TELECOM ENLARGED PLANS AND ELEVATIONS
•	•	•	•	T501	AUDIOVISUAL INFRASTRUCTURE ROOM RISERS
•	•	•	•	T502	AUDIOVISUAL INFRASTRUCTURE ROOM RISERS
•	•	•	•	T503	AUDIOVISUAL INFRASTRUCTURE ROOM RISERS
•	•	•	•	T601	TYPICAL TELECOM BUILDING RISER
•	•	•	•	T602	TYPICAL TELECOM RISER
•	•	•	•	T701	TECHNOLOGY INFRASTRUCTURE ELEVATIONS
•	•	•	•	T801	TECHNOLOGY INFRASTRUCTURE DETAILS
•	•	•	•	T802	TECHNOLOGY INFRASTRUCTURE DETAILS
•	•	•	•	T901	TYPICAL TELECOM DETAILS

Van Buren Charter Township

Van Buren Township, MI

The Lakeside Park

fishbeck

Engineers | Architects | Scientists | Constructors

REVISIONS

10/12/2026 BID AND PERMIT SET

Drawn By TGAUNTNER
Designer JFISHMAN, TROBINETTE
Reviewer DCHITTY, KKERSTETTER
Manager KKERSTETTER, CKRETTOVIC

Hard copy is intended to be 24"x36" when plotted. Scale(s) indicated and graphic quality may not be accurate for any other size.

PROJECT NO.

2500281

SHEET NO.

T001

©Copyright 2026 All Rights Reserved

TECHNOLOGY JUNCTION BOX LEGEND										
TYPE		FUNCTION	ENCLOSURE DIMENSIONS			ENCLOSURE DESCRIPTION	ENCLOSURE MAKE & MODEL	MOUNTING STYLE	REFERENCE DETAIL	LEGEND NOTES
SYM	STYLE		LENGTH	WIDTH	DEPTH					
F2	FLOOR	FLOOR BOX W/ AV TELECOM AND POWER	11 5/16"	15 1/8"	6"	FLOOR BOX	WIREMOLD EF88S	FLUSH WITH FINISHED FLOOR	2/T801	A, B
C1	WALL	CAMERA PULL BOX	4 11/16"	4 11/16"	2 1/8"	PULL BOX W/ RAISED TWO-DEVICE COVER	RACO 258 259 OR 265	96" AFF - FLUSH (UNO)	1/T801	-
D8	WALL	DISPLAY BOX W/ AV TELECOM AND POWER	10 7/8"	11 1/4"	3 7/8"	DISPLAY BOX	WIREMOLD EFSB4	FLUSH (UNO) - REFER TO ROOM DISPLAY SCHEDULE AND ELEVATIONS	3, 4/T801	C
L2	WALL	OUTDOOR LOUDSPEAKER PULL BOX	4 11/16"	4 11/16"	2 1/8"	OUTDOOR RATED PULL BOX	OUTDOOR RATED	90" AFF - FLUSH (UNO)	-	-
PS2	WALL	PARTITION SENSOR WALL BOX	4 11/16"	4 11/16"	2 1/8"	PULL BOX W/ FLAT COVER	RACO 258 259 OR 265	120" AFF - FLUSH (UNO)	-	-
R8	WALL	EQUIPMENT RACK PULL BOX W/ AV TELECOM AND POWER	12 3/8"	12 3/8"	4"	PULL BOX W/ PAINTED SCREW COVER	FSR WB-X2-GNG	PER PROJECT STANDARD OUTLET HEIGHT - FLUSH (UNO) - REFER TO ARCH. DRAWINGS	5, 6/T801	D
S2	WALL	PROJECTION SCREEN CONTROL SWITCH (DUAL)	4 11/16"	4 11/16"	2 1/8"	PULL BOX W/ RAISED TWO-DEVICE COVER	RACO 258 259 OR 265	PER PROJECT STANDARD SWITCH HEIGHT - FLUSH (UNO) - REFER TO ARCH. DRAWINGS	-	E, G
TP2	WALL	CONTROL PANEL W/ AV AND TELECOM	4 11/16"	4 11/16"	2 1/8"	PULL BOX W/ RAISED TWO-DEVICE COVER	RACO 258 259 OR 265	PER PROJECT STANDARD SWITCH HEIGHT - FLUSH (UNO) - REFER TO ARCH. DRAWINGS	-	-
W17	WALL	AV IO PANEL W/ AV TELECOM AND POWER	4 11/16"	10 7/16"	2 1/2"	PULL BOX W/ RAISED FOUR-DEVICE COVER	RACO 943	36" AFF - FLUSH (UNO)	7/T801	-
D41-1	CEILING	DISPLAY PULL BOX	4 11/16"	4 11/16"	2 1/8"	PULL BOX W/ FLAT COVER	RACO 258 259 OR 265	18" ABOVE ACCESSIBLE CEILING	-	-
IS1-3	CEILING	OCCUPANCY SENSOR	4 11/16"	4 11/16"	2 1/8"	PULL BOX W/ FLAT COVER	RACO 258 259 OR 265	SUSPENDED FROM DECK - FLUSH WITH CEILING	-	-
J6	CEILING	CONDUIT CONSOLIDATION PULL BOX	18"	18"	6"	PULL BOX (PUNCHED AS REQUIRED) W/ PAINTED SCREW COVER	HOFFMAN A-SE18X18X6NKN	18" ABOVE ACCESSIBLE CEILING	-	-
L11-1	CEILING	LOUDSPEAKER PULL BOX	4 11/16"	4 11/16"	2 1/8"	PULL BOX W/ FLAT COVER	RACO 258 259 OR 265	18" ABOVE ACCESSIBLE CEILING	1/T802	-
M1-1	CEILING	MICROPHONE PULL BOX	4 11/16"	4 11/16"	2 1/8"	PULL BOX W/ FLAT COVER	RACO 258 259 OR 265	18" ABOVE ACCESSIBLE CEILING	-	-
PJ1	CEILING	PROJECTOR LIFT	20"	36 9/32"	37 11/16"	MOTORIZED PROJECTOR LIFT ASSEMBLY	DRAPER SCISSOR SLX	SUSPENDED FROM DECK - FLUSH WITH CEILING	2/T802	E, F

TECHNOLOGY TELECOM JUNCTION BOX LEGEND										
TYPE		FUNCTION	ENCLOSURE DIMENSIONS			ENCLOSURE DESCRIPTION	ENCLOSURE MAKE & MODEL	MOUNTING STYLE	REFERENCE DETAIL	LEGEND NOTES
SYM	STYLE		LENGTH	WIDTH	DEPTH					
N1	FLOOR	TELECOM OUTLET - FLOOR	-	-	-	FLOOR DEVICE INDICATED BY BOX NUMBER	COORDINATE W/ ASSOCIATED FLOOR DEVICE	INSTALL IN FLOOR DEVICE PER MFR DIRECTIONS	2/T801	A, B, H
N2	WALL	TELECOM OUTLET - DISPLAY	-	-	-	WALL BOX INDICATED BY BOX NUMBER	COORDINATE W/ ASSOCIATED DISPLAY BOX	INSTALL IN DISPLAY BOX PER MFR DIRECTIONS	3, 4/T801	C, H
N3	WALL	TELECOM OUTLET - EQUIPMENT RACK	-	-	-	WALL BOX INDICATED BY BOX NUMBER	COORDINATE W/ ASSOCIATED EQUIPMENT RACK BOX	INSTALL IN EQUIPMENT RACK BOX PER MFR DIRECTIONS	5, 6/T801	D, H
N4	WALL	TELECOM OUTLET - STANDARD	4 11/16"	4 11/16"	2 1/8"	PULL BOX W/ RAISED ONE-DEVICE COVER	RACO 258 259 OR 265	PER PROJECT STANDARD OUTLET HEIGHT - FLUSH (UNO) - REFER TO ARCH. DRAWINGS	-	H, I
N6	WALL	TELECOM OUTLET - ABOVE COUNTER	4 11/16"	4 11/16"	2 1/8"	PULL BOX W/ RAISED ONE-DEVICE COVER	RACO 258 259 OR 265	PER PROJECT STANDARD COUNTER OUTLET HEIGHT - FLUSH (UNO) - REFER TO ARCH. DRAWINGS	-	H
N9	WALL	TELECOM OUTLET - IN RACEWAY	4 11/16"	4 11/16"	2 1/8"	PULL BOX W/ RAISED ONE-DEVICE COVER	RACO 258 259 OR 265	120" AFF - FLUSH	-	H
N10	WALL	TELECOM OUTLET - WAP	4 11/16"	4 11/16"	2 1/8"	PULL BOX W/ RAISED ONE-DEVICE COVER	RACO 258 259 OR 265	120" AFF - FLUSH	-	-
N11	WALL	TELECOM OUTLET - SECURITY CAMERA	4 11/16"	4 11/16"	2 1/8"	PULL BOX W/ RAISED ONE-DEVICE COVER	RACO 258 259 OR 265	120" AFF - FLUSH	-	H
N13	WALL	TELECOM OUTLET - UTILITY	4 11/16"	4 11/16"	2 1/8"	PULL BOX W/ RAISED ONE-DEVICE COVER	RACO 258 259 OR 265	COORDINATE WITH APPLICABLE TRADE	-	H
N14	WALL	TELECOM PULL BOX - TOUCH OR SCHEDULING PANEL	-	-	-	WALL BOX INDICATED BY BOX NUMBER	COORDINATE W/ ASSOCIATED TOUCH OR SCHEDULING PANEL BOX	INSTALL NETWORK JACK WITHIN ASSOCIATED TOUCH OR SCHEDULING PANEL BOX	-	H
N15	WALL	TELECOM OUTLET - AV IO PANEL	-	-	-	AV IO PANEL INDICATED BY BOX NUMBER	COORDINATE W/ ASSOCIATED AV IO PANEL	INSTALL IN AV IO PANEL PER MFR DIRECTIONS	7/T801	H
N16	WALL	TELECOM OUTLET - POLE-MOUNT CAMERA	4 11/16"	4 11/16"	2 1/8"	PULL BOX	RACO 258 259 OR 265	REFER TO ARCH. DRAWINGS	-	-
N21-1	CEILING	TELECOM OUTLET - DISPLAY	4 11/16"	4 11/16"	2 1/8"	PULL BOX W/ BLANK COVER	RACO 258 259 OR 265	18" ABOVE ACCESSIBLE CEILING	-	H
N23-1	CEILING	TELECOM OUTLET - WAP	4 11/16"	4 11/16"	2 1/8"	PULL BOX W/ BLANK COVER	RACO 258 259 OR 265	18" ABOVE ACCESSIBLE CEILING	-	H
N24-1	CEILING	TELECOM OUTLET - SECURITY CAMERA	4 11/16"	4 11/16"	2 1/8"	PULL BOX W/ BLANK COVER	RACO 258 259 OR 265	18" ABOVE ACCESSIBLE CEILING	-	H
N24-3	CEILING	TELECOM OUTLET - SECURITY CAMERA	4 11/16"	4 11/16"	2 1/8"	PULL BOX W/ RAISED ONE-DEVICE COVER	RACO 258 259 OR 265	SUSPENDED FROM DECK - FLUSH WITH CEILING	-	H

TECHNOLOGY POWER LEGEND										
TYPE		FUNCTION	VOLTS	AMPS	NEMA	DESCRIPTION	ADDITIONAL REQUIREMENTS	MOUNTING STYLE	REFERENCE DETAIL	LEGEND NOTES
SYM	STYLE									
P1	FLOOR	POWER RECEPTACLE - FLOOR DEVICE	120	20	5-20R	DUPLEX RECEPTACLE INSIDE FLOOR DEVICE	-	INSTALL IN FLOOR DEVICE PER MFR DIRECTIONS	2/T801	A, B, J
P2	WALL	POWER RECEPTACLE - DISPLAY	120	20	5-20R	DUPLEX RECEPTACLE INSIDE DISPLAY BOX	-	INSTALL IN DISPLAY BOX PER MFR DIRECTIONS	3, 4/T801	C, J
P3	WALL	POWER RECEPTACLE - EQUIPMENT RACK	120	20	5-20R	DUPLEX RECEPTACLE INSIDE EQUIPMENT RACK BOX	-	INSTALL IN EQUIPMENT RACK BOX PER MFR DIRECTIONS	5, 6/T801	D, J
P7	WALL	POWER RECEPTACLE - TECHNOLOGY RACK	120	20	5-20R	DOUBLE DUPLEX RECEPTACLE (DUAL CIRCUIT)	TWO DEDICATED CIRCUITS	PER PROJECT STANDARD OUTLET HEIGHT - FLUSH (UNO) - REFER TO ARCH. DRAWINGS	-	J
P15	WALL	POWER RECEPTACLE - AV IO PANEL	120	20	5-20R	DUPLEX RECEPTACLE INSIDE AV IO PANEL	-	INSTALL IN AV IO PANEL PER MFR DIRECTIONS	7/T801	J
P16	WALL	POWER CIRCUIT - ACCESS CONTROL PANEL	120	20	-	HARDWIRED POWER CIRCUIT DIRECT TO ACCESS CONTROL PANEL	DEDICATED CIRCUIT	REFER TO PLANS & ELEVATIONS	-	J
P17	WALL	POWER RECEPTACLE - CONVENIENCE DUPLEX	120	20	5-20R	DUPLEX RECEPTACLE	-	PER PROJECT STANDARD OUTLET HEIGHT - FLUSH (UNO) - REFER TO ARCH. DRAWINGS	-	J
P18	WALL	POWER RECEPTACLE - TELECOM RACK	208	30	L6-30R	TWIST-LOCK RECEPTACLE	DEDICATED CIRCUIT	MOUNT TO CABLE RUNWAY ABOVE EQUIPMENT RACK	-	J
P22	CEILING	POWER CIRCUIT - MOTORIZED PROJECTION SCREEN	120	20	-	WORKBOX W/ POWER CIRCUIT	-	TERMINATE AT PROJECTION SCREEN PER MFR INSTRUCTIONS	-	G, J
P23	CEILING	POWER CIRCUIT - MOTORIZED PROJECTOR LIFT	120	20	-	WORKBOX W/ POWER CIRCUIT	DEDICATED CIRCUIT	TERMINATE AT PROJECTOR LIFT PER MFR INSTRUCTIONS	2/T802	E, G, J

TELECOM CABLING LEGEND						
TYPE	CAT6A	FIBER	COAX	REFERENCE DETAIL	NOTES	
A	1	0	0	1/T901	-	
B	2	0	0	1/T901	-	
C	3	0	0	1/T901	-	
D	4	0	0	1/T901	-	
E	6	0	0	1/T901	-	
G	1	0	0	1/T901	DIRECT CONNECT	

TECHNOLOGY LEGEND NOTES	
[A] FLOOR BOXES AND FLOOR PENETRATIONS: VERIFY EXACT LOCATION, COVER STYLE AND FINISH WITH ARCHITECT PRIOR TO INSTALLATION. PROVIDE ON-GRADE OR FIRE-RATED VERSION FLOOR BOXES AS REQUIRED.	
[B] F2(N1, P1) FLOOR BOX CONFIGURATION: WIREMOLD EVOLUTION SERIES EF88S-OG FLOOR BOX WITH FINISHED COVER. VERIFY COVER STYLE AND FINISH WITH ARCHITECT PRIOR TO ORDERING. INCLUDED COMPONENTS: TEMPORARY CONSTRUCTION COVER, TUNNEL SYSTEM, TWO REMOVABLE MODULES, CABLE MANAGEMENT GUIDES, MOUNTING CLAMPS AND LEVELING SUPPORT LEGS. PROVIDE AS REQUIRED: POWER RECEPTACLES, COMMUNICATION JACKS, MOUNTING BRACKETS, DEVICE PLATES, BLANK DEVICE PLATES, DIVIDER PLATES, AND OTHER ACCESSORIES AS NEEDED. CONFIGURE BOX ACCORDING TO DETAILS. VERIFY EXACT LOCATION WITH ARCHITECT PRIOR TO INSTALLATION.	
[C] D8(N2, P2) FLAT PANEL DISPLAY BOX CONFIGURATION: WIREMOLD EVOLUTION SERIES EFSB4 FLAT PANEL DISPLAY WALL BOX. VERIFY COVER COLOR WITH ARCHITECT PRIOR TO ORDERING. INCLUDED COMPONENTS: TUNNEL, DEVICE MODULES, TRIM FLANGE, AND DECORATIVE COVER. PROVIDE AS REQUIRED: POWER RECEPTACLES, COMMUNICATION JACKS, DEVICE PLATES, BLANK DEVICE PLATES, KNOCKOUT PLATES, AND OTHER ACCESSORIES AS NEEDED. CONFIGURE BOX ACCORDING TO DETAILS.	
[D] R8(N3, P3) LARGE CAPACITY WALL BOX CONFIGURATION: FSR WB-X2-GNG LARGE CAPACITY WALL BOX WITH LOCKING COVER. VERIFY COVER COLOR AND STYLE WITH ARCHITECT PRIOR TO ORDERING. INCLUDED COMPONENTS: INTERNAL BRACKETS, CENTER DIVIDERS, AND MOUNTING BRACKETS. PROVIDE AS REQUIRED: POWER RECEPTACLES, COMMUNICATION JACKS, DEVICE PLATES, BLANK DEVICE PLATES, AND OTHER ACCESSORIES AS NEEDED. CONFIGURE BOX ACCORDING TO DETAILS.	
[E] PROJECTOR LIFT: DRAPER SCISSOR LIFT SLX SCISSOR LIFT WITH ENOUGH TRAVEL TO EXTEND TO 6" AFF. PROVIDE OPTIONAL CEILING CLOSURE PANEL OR OPTIONAL ENVIRONMENTAL AIR SPACE HOUSING AS REQUIRED, AS WELL AS CEILING FINISH KIT. COORDINATE FINISH WITH ARCHITECT PRIOR TO ORDERING.	
[F] CEILING SUSPENDED VIDEO PROJECTOR: THE LOCATION OF THE AUDIOVISUAL, POWER AND TELECOM JUNCTION BOXES IN RELATION TO THE PROJECTION SCREEN IS CRITICAL. FOR VIDEO PROJECTOR INFRASTRUCTURE LAYOUT INFORMATION REFER TO THE "TYPICAL PROJECTION SCREEN DETAIL" AND OTHER REFERENCED DETAILS.	
[G] PROJECTION SCREEN LOW VOLTAGE CONTROL SYSTEM: PROVIDE AC LINE VOLTAGE CONNECTION TO SCREEN CONTROL INTERFACE BUILT INTO MOTORIZED PROJECTION SCREEN HOUSING PER MANUFACTURER'S INSTRUCTION. PROVIDE LOW VOLTAGE WIRING CONNECTION FROM SCREEN CONTROL INTERFACE TO WALL MOUNTED PROJECTION SCREEN WALL SWITCH PER MANUFACTURER'S INSTRUCTION.	
[H] TELECOM OUTLETS AND ASSOCIATED CONDUITS: CONDUIT MUST BE PROVIDED FOR ALL TELECOM JUNCTION BOXES. SEE THE "TELECOM TYPICAL CONDUIT RISER" FOR CONDUIT REQUIREMENTS BY TELECOM JUNCTION BOX TYPE. REFER TO THE TELECOM PLANS FOR THE LOCATIONS OF JUNCTION BOXES AND FLOOR BOXES, AND THE "TELECOM CABLING LEGEND" FOR OUTLET CONFIGURATION REQUIREMENTS. TELECOM CABLING, OUTLETS AND COVER PLATES PROVIDED BY THE STRUCTURED CABLING SYSTEMS CONTRACTOR.	
[I] POWER RECEPTACLES ADJACENT TO INDICATED TELECOM WALL OUTLETS: INDICATED TELECOM WALL OUTLETS SHALL HAVE A DUPLEX POWER RECEPTACLE LOCATED WITHIN 36" OF THE TELECOM WALL OUTLET. IDEALLY, THE TELECOM OUTLET BOX WILL BE MOUNTED TO ONE SIDE OF A STUD, AND THE POWER BOX TO THE OPPOSITE SIDE OF THE STUD.	
[J] POWER RECEPTACLES AND DIRECT CIRCUIT CONNECTIONS: TECHNICAL POWER RECEPTACLES AND DIRECT CIRCUIT CONNECTIONS, INCLUDING THOSE WITHIN FLOOR BOXES, WALL BOXES, OR CEILING BOXES, ARE PROVIDED BY ELECTRICAL CONTRACTOR AND APPEAR ON THE ELECTRICAL DRAWINGS. TECHNICAL POWER APPEARS ON THE TECHNOLOGY INFRASTRUCTURE DRAWINGS FOR COORDINATION AND LOCATION PURPOSES. THE LOCATION OF TECHNICAL POWER IN RELATION TO OTHER TECHNOLOGY INFRASTRUCTURE MAY BE CRITICAL. REFER TO THE ELECTRICAL DRAWINGS FOR COMPLETE POWER LAYOUTS AND CIRCUITING DETAILS.	



Engineers | Architects | Scientists | Constructors

Van Buren Charter Township

Van Buren Township, MI

The Lakeside Park

10/12/2026 - BID AND PERMIT SET

Drawn By	TGAUNTNER
Designer	JFISHMAN, TROBINETTE
Reviewer	DCHITTY, KKERSTETTER
Manager	CKRETOVIC

Hard copy is intended to be 24"x36" when plotted. Scale(s) indicated and graphic quality may not be accurate for any other size.

PROJECT NO.

2500281

SHEET NO.


T002

©Copyright 2026
All Rights Reserved

PLOT INFO: 10/22/2026 10:52:00 AM Autodesk Docs://2500281 - Van Buren Twp Lake House2026_T_2500281.rvt



1
T003

TYPICAL PROJECTION SCREEN / VIDEO PROJECTOR RELATIONSHIP
NTS

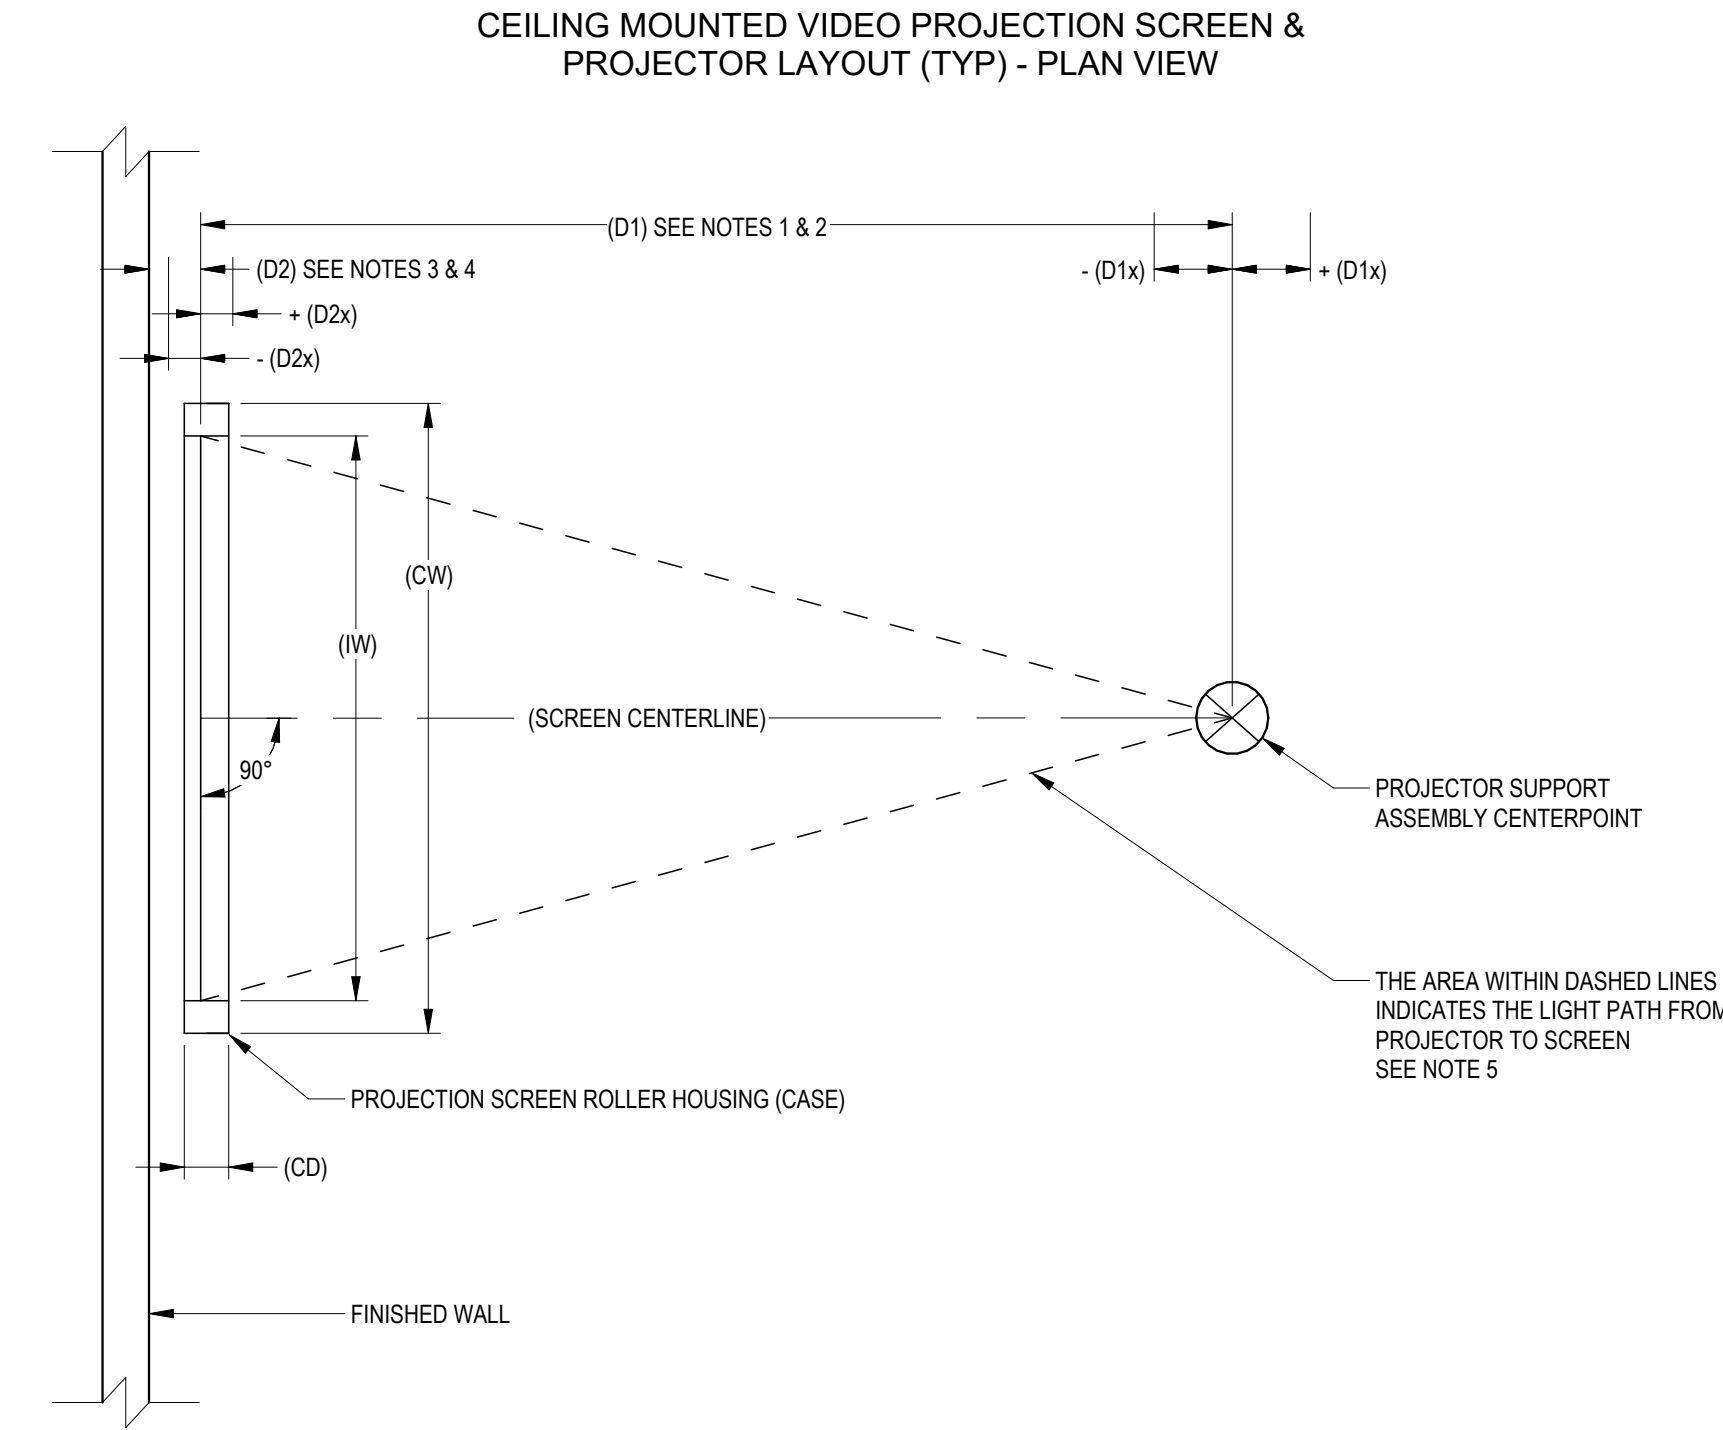

PROJECTION SCREEN / VIDEO PROJECTOR RELATIONSHIP NOTES

- [D1] – CRITICAL DISTANCE: D1 IS THE DISTANCE FROM THE PROJECTION SCREEN SURFACE TO THE CENTER OF THE PROJECTOR CEILING MOUNT ASSEMBLY.
 - IMPORTANT: IF DISTANCE D2 IS ADJUSTED, D1 MUST REMAIN CONSTANT.
- [D1X] – ALLOWABLE D1 VARIANCE: D1X DEFINES THE PERMISSIBLE ± VARIANCE FOR D1 TO ACCOMMODATE STRUCTURAL OR OTHER OBSTRUCTIONS.
 - EXAMPLE: IF D1 = 300" AND D1X = 10", THE PROJECTOR CEILING MOUNT CENTER MAY BE LOCATED BETWEEN 290" AND 310" FROM THE SCREEN SURFACE ALONG THE SCREEN CENTERLINE.
- [D2] – MINIMUM PROJECTION WALL CLEARANCE: D2 IS THE MINIMUM DISTANCE FROM THE PROJECTION WALL TO THE PROJECTION SCREEN SURFACE.
 - IF D2 MUST INCREASE BEYOND D2 + D2X TO AVOID OBSTRUCTIONS, CONTACT THE CONSULTANT FOR DIRECTION.
- [D2X] – ALLOWABLE D2 VARIANCE: D2X DEFINES THE PERMISSIBLE ± VARIANCE FOR D2.
 - EXAMPLE: IF D2 = 6" AND D2X = 2", THE SCREEN SURFACE MAY BE LOCATED BETWEEN 4" AND 8" FROM THE PROJECTION WALL ON THE SCREEN CENTERLINE.
- CLEAR PROJECTION PATH: THE PROJECTOR MUST HAVE AN UNOBSTRUCTED VIEW OF THE ENTIRE SCREEN IMAGE AREA AT ALL TIMES.
- [BLACK DROP] – FIELD VERIFICATION REQUIRED: THE BLACK DROP AMOUNT LISTED IN THE ROOM PROJECTION SCREEN SCHEDULE IS A DESIGN ESTIMATE.
 - FIELD-VERIFY EACH SCREEN PRIOR TO SUBMITTAL.
 - REQUIRED BLACK DROP (BD) = (RHAFF) – (IHAFF + IH)
 - RHAFF: ROLLER HOUSING ELEVATION ABOVE FINISHED FLOOR
 - IHAFF: BOTTOM OF IMAGE HEIGHT ABOVE FINISHED FLOOR
 - IH: IMAGE HEIGHT
 - EXCESS BLACK DROP REMAINING ON THE ROLLER WHEN THE SCREEN IS DEPLOYED SHOULD NOT EXCEED ONE WRAP.
 - IF ACTUAL CEILING HEIGHT DIFFERS FROM DRAWINGS, THE SPECIFIED IMAGE HEIGHT ABOVE FINISHED FLOOR (IHAFF) GOVERNS.
- POWER JUNCTION BOX LOCATION: LOCATE THE PROJECTION SCREEN POWER JUNCTION BOX ON THE SAME SIDE AS THE SCREEN'S ELECTRICAL CONNECTIONS (VARIES BY SCREEN TYPE). VERIFY LOCATION PRIOR TO INSTALLATION.

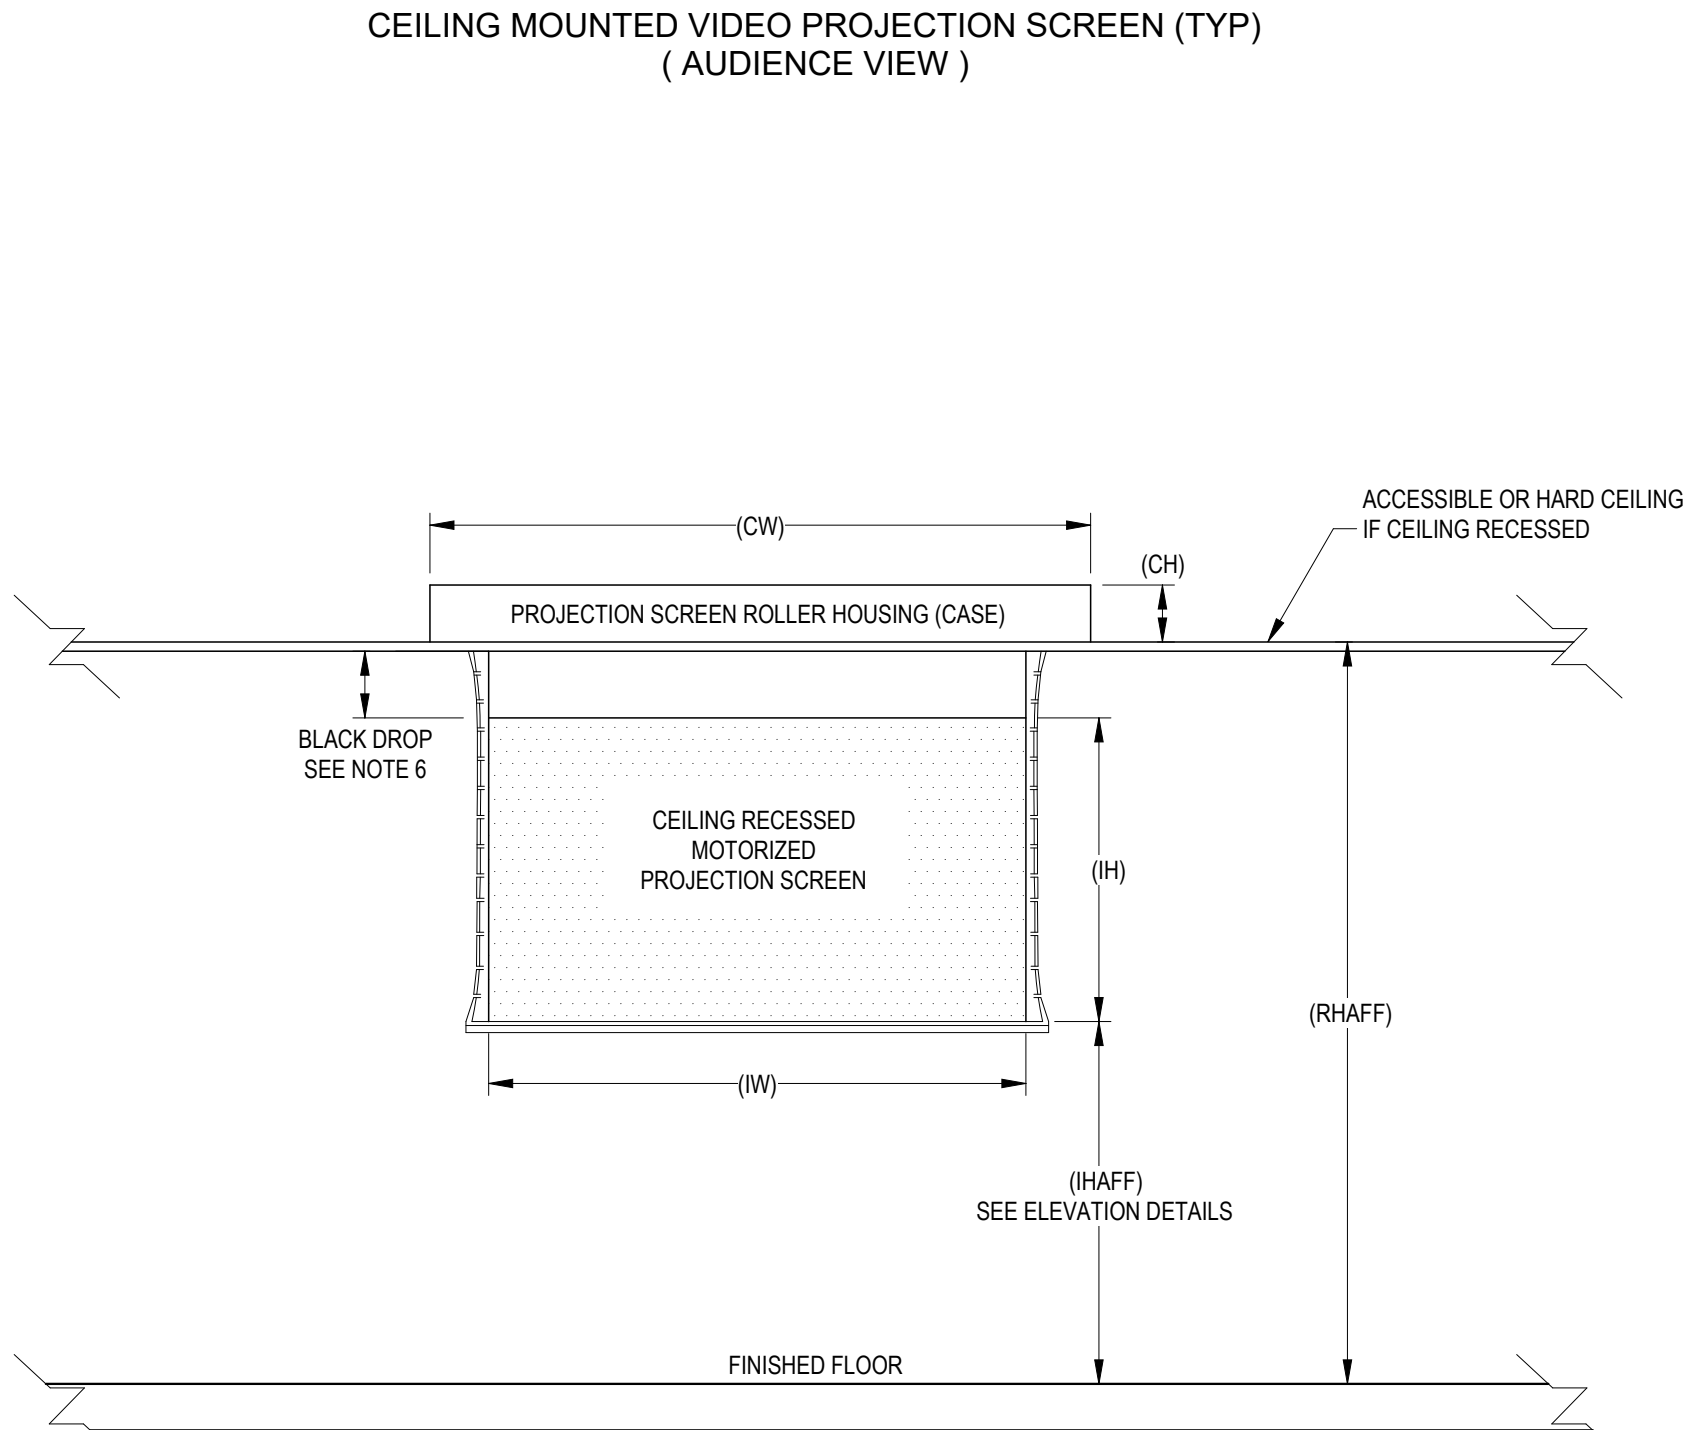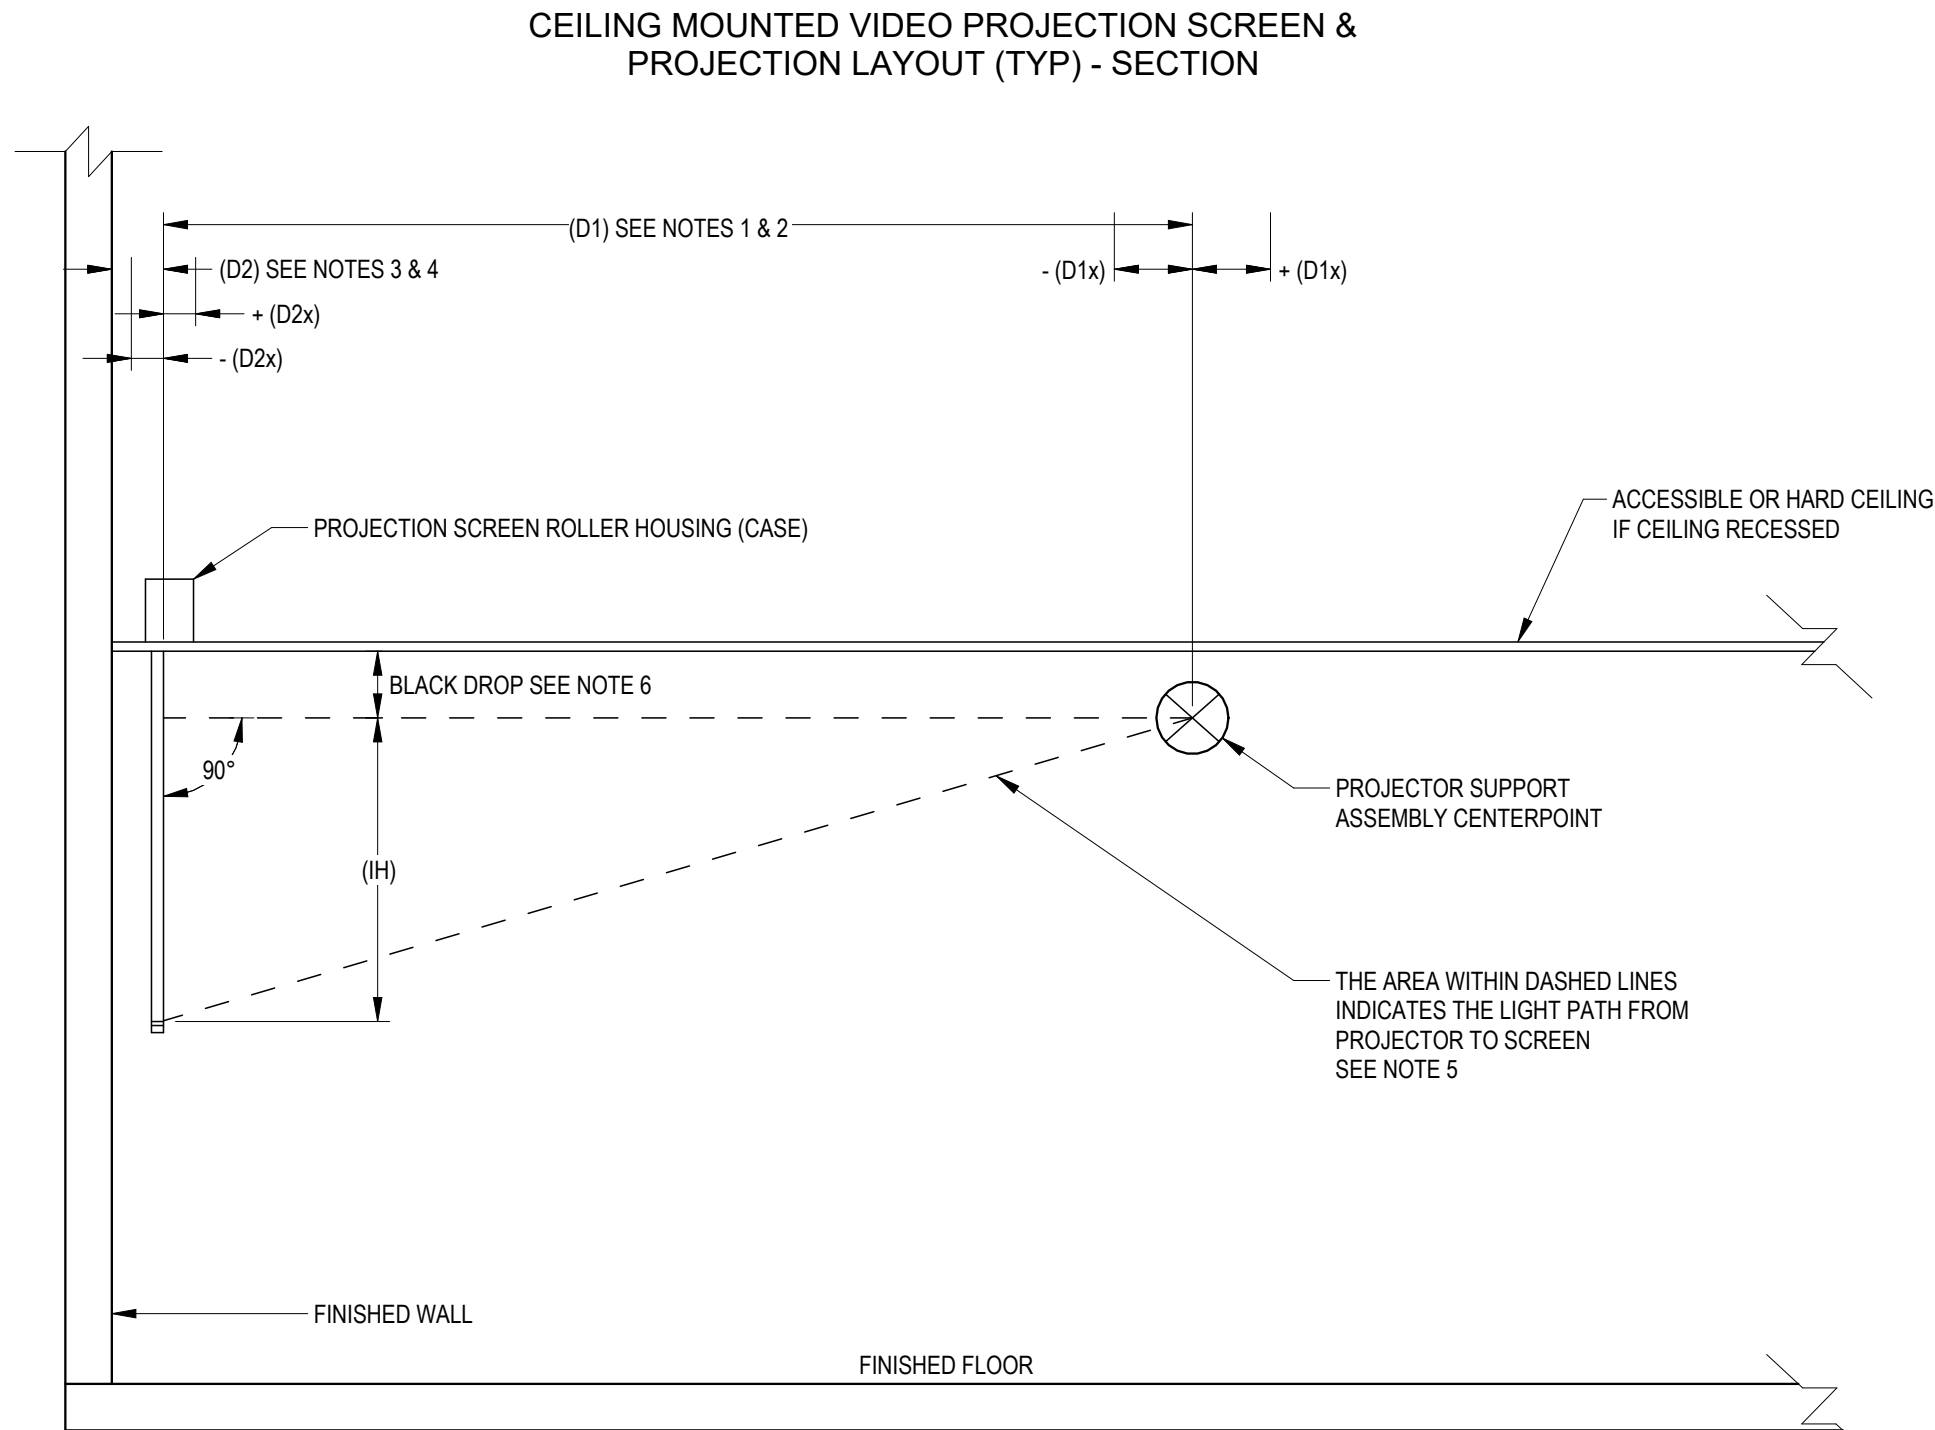

Van Buren Charter Township

Van Buren Township, MI

The Lakeside Park

fishbeck

Engineers | Architects | Scientists | Constructors

REVISIONS

10/12/2026 BID AND PERMIT SET

Drawn By TGAUNTNER
Designer JFISHMAN, TROBINETTE
Reviewer DCHITTY, KKERSTETTER
Manager CKRETOVIC

Hard copy is intended to be 24"x36" when plotted. Scale(s) indicated and graphic quality may not be accurate for any other size.

PROJECT NO.
2500281

SHEET NO.

T003

©Copyright 2026
All Rights Reserved

PROJECTION SCREEN TYPE LEGEND

TYPE	IMAGE SIZE		CASE SIZE			WEIGHT (lbs)	INSTALLATION	OPERATION	MAKE & MODEL	IMAGE SURFACE MATERIAL	CONTROL	CASE PROVIDED BY	FABRIC & ROLLER PROVIDED BY	REFERENCE DETAIL
	HEIGHT (IH)	WIDTH (IW)	HEIGHT (CH)	WIDTH (CW)	DEPTH (CD)									
A	65"	116"	7' 15/16"	132 1/2"	7 3/4"	100	CEILING MOUNTED - FLUSH	MOTORIZED	DA-LITE TENSIONED ADVANTAGE WITH SIGHTLINE	PARALLAX STRATOS 1.0	INTERNAL LVC	GENERAL CONTRACTOR	GENERAL CONTRACTOR	1/T003, 3/T802

DISPLAY TYPE LEGEND

TYPE	NOMINAL IMAGE DIAGONAL	NOMINAL CASE SIZE			NOMINAL WEIGHT (lbs)	BACKING	
		HEIGHT (H)	WIDTH (W)	DEPTH (D)		HEIGHT (H)	WIDTH (W)
55	55"	29"	50"	4"	60	24"	48"
65	65"	34"	59"	4"	77	24"	48"
98	98"	49"	87"	4"	183	48"	96"


ROOM PROJECTION SCREEN SCHEDULE

ROOM NUMBER	QTY	SCREEN TYPE	SCREEN			PROJECTOR MOUNT		
			BOTTOM OF IMAGE AFF	BLACK DROP (EST)	DISTANCE [D2]	DISTANCE [D2x]	DISTANCE [D1]	DISTANCE [D1x]
	2	A	54"	6"	7"	0"	201"	18"


ROOM DISPLAY SCHEDULE

VERTICAL AND HORIZONTAL CENTERLINE OF THE DISPLAY AND BACK BOX MAY DIFFER. REFER TO ELEVATIONS.				
ROOM NUMBER	DISPLAY QTY	DISPLAY TYPE	ELEV AFF OC	COMMENTS
104	1	55	80"	
105	2	98	72"	
118	1	65	66"	

PLOT INFO: 10/2/2026 10:52:04 AM Autodesk Docs://2500281 - Van Buren Twp Lake House2026_T_2500281.rvt

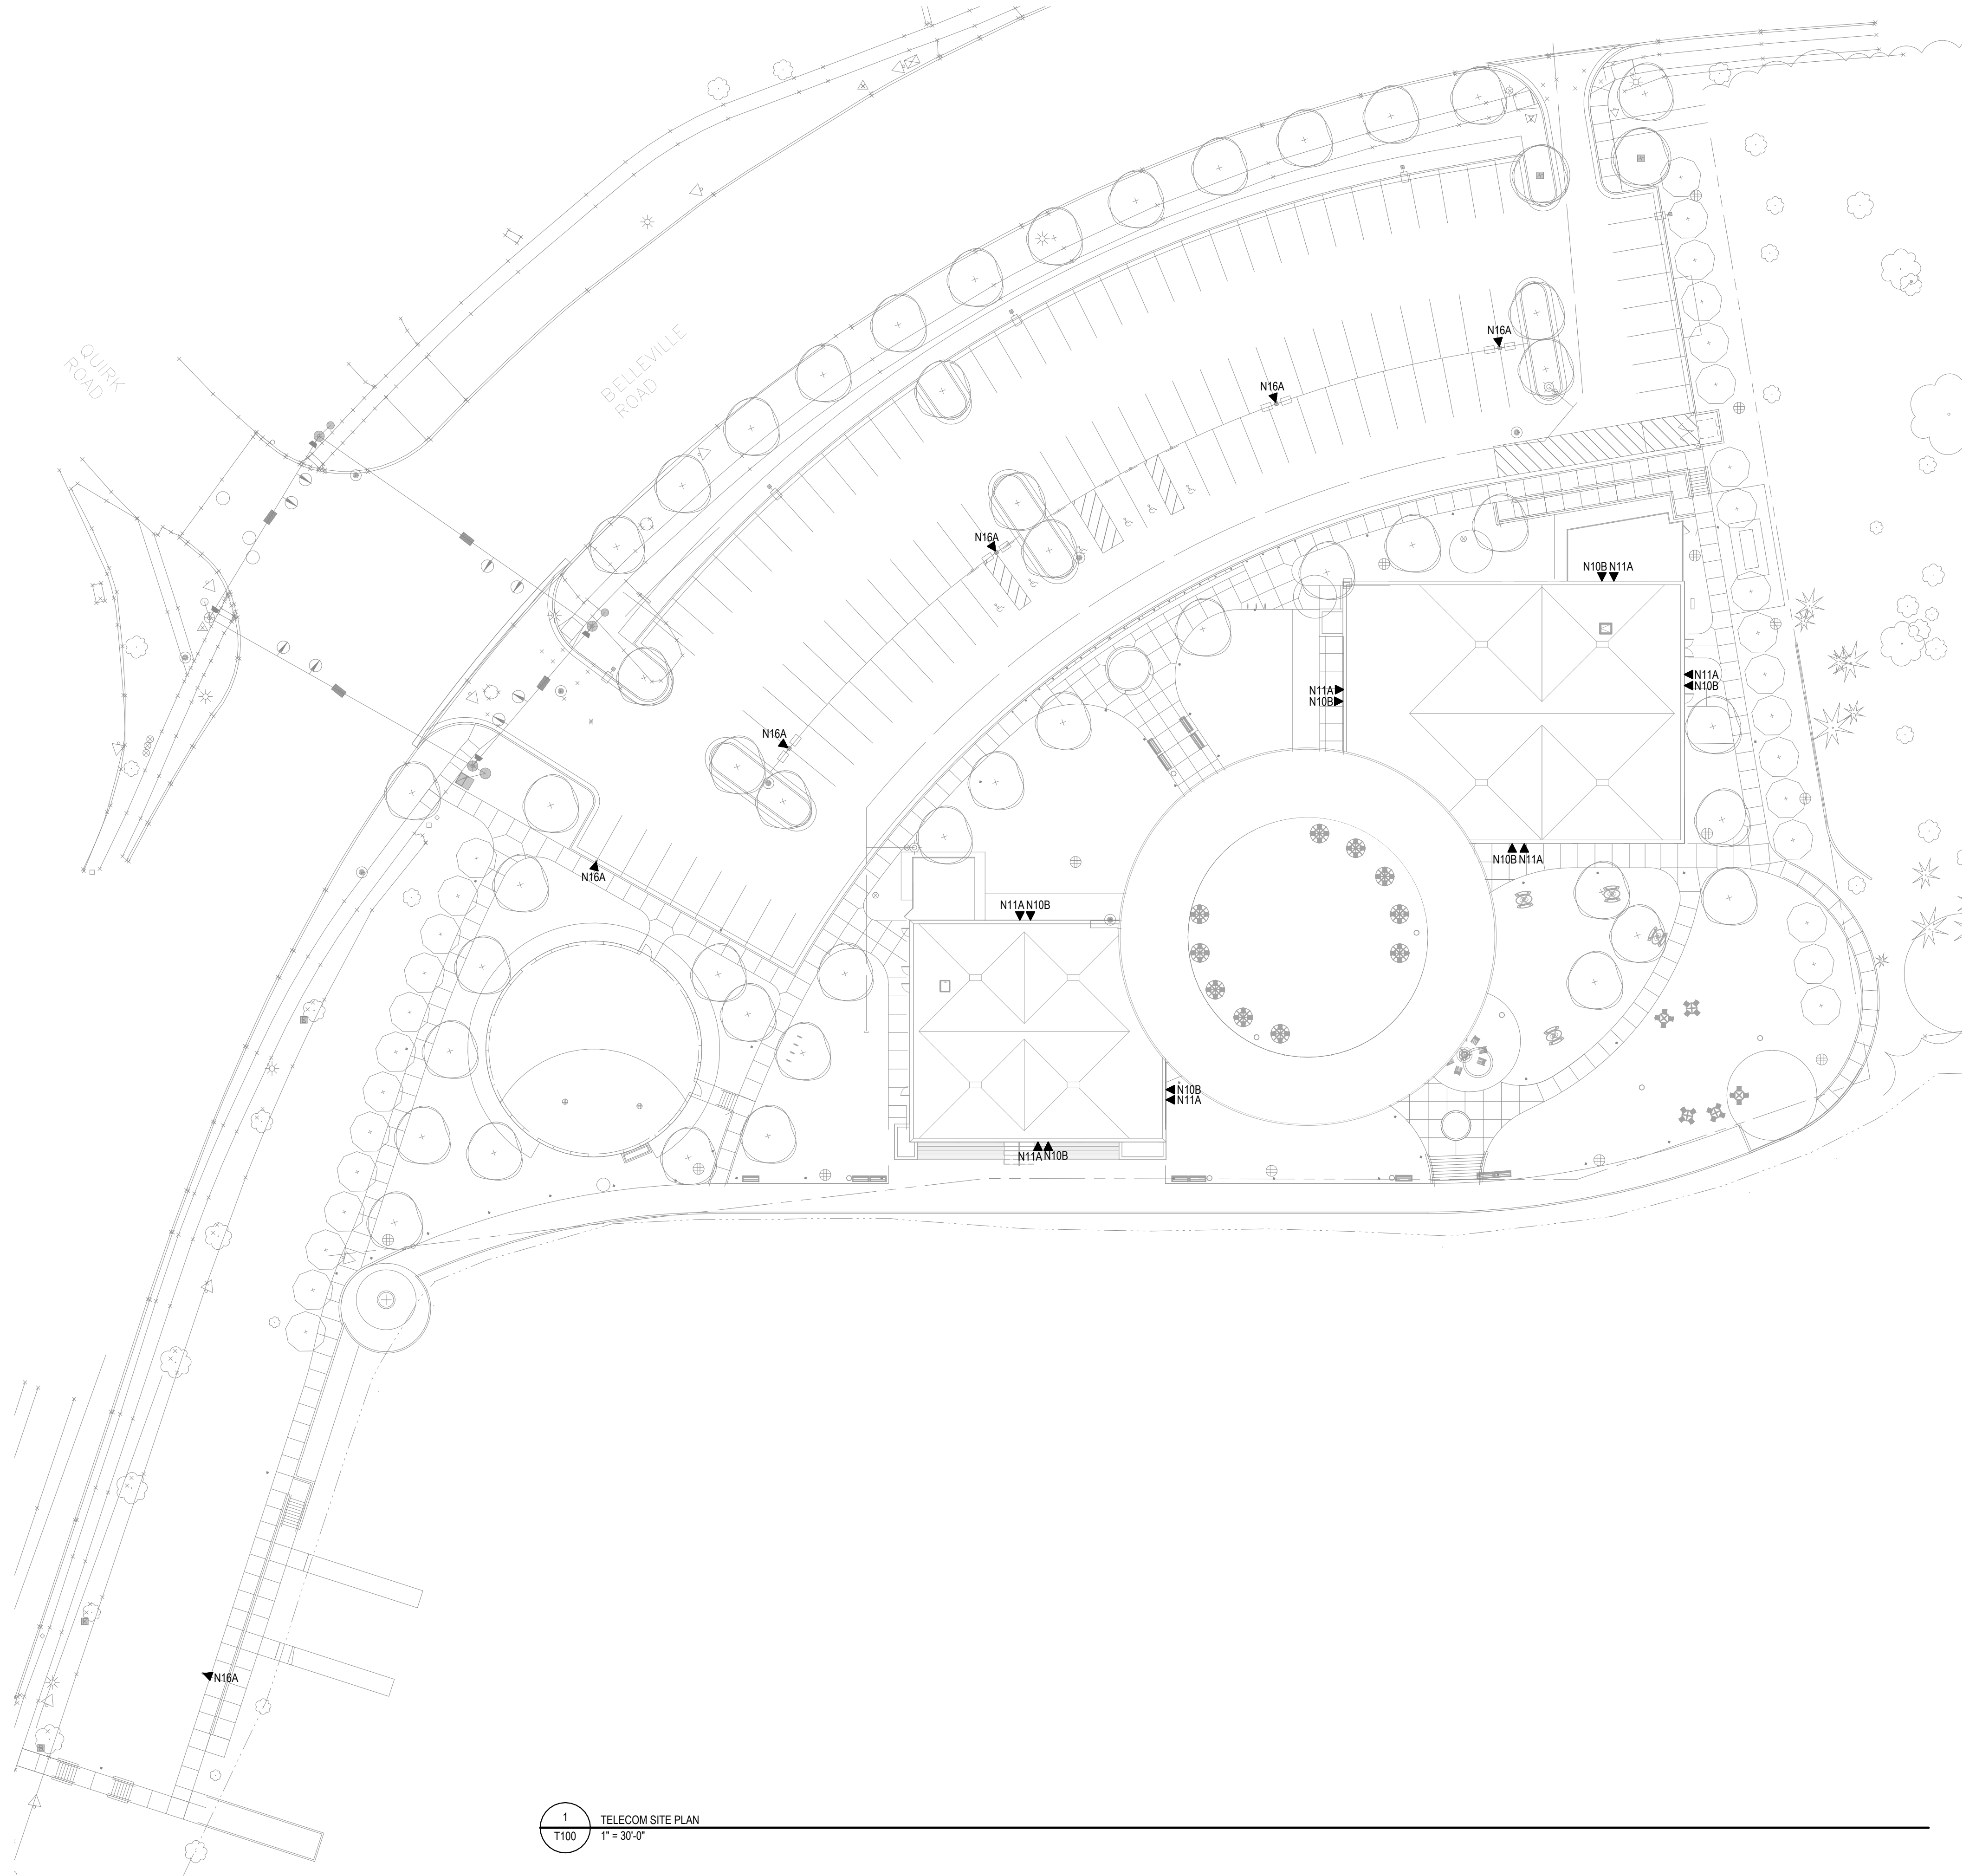

KEY PLAN

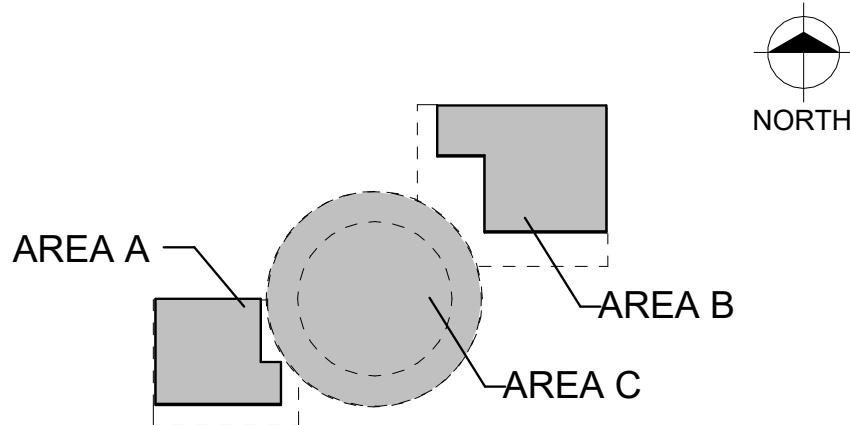

Van Buren Charter Township

Van Buren Township, MI

The Lakeside Park

REVISIONS

10/12/2026	BID AND PERMIT SET
Drawn By	TGAUNTNER
Designer	JFISHMAN, TROBINETTE
Reviewer	DGHITY, KKERSTETTER
Manager	CKRETOVIC

Hard copy is intended to be 24"x36" when plotted. Scale(s) indicated and graphic quality may not be accurate for any other size.

PROJECT NO.
2500281

SHEET NO.

T100

©Copyright 2026
All Rights Reserved

Van Buren Township, MI

The Lakeside Park

1	REFER TO SHEET T001 FOR ALL TECHNOLOGY INFRASTRUCTURE GENERAL NOTES, LEGENDS, ABBREVIATIONS, AND SHEET INDEX.
2	REFER TO SHEET T002 & T003 FOR ALL INFRASTRUCTURE SCHEDULES AND LEGENDS



10/12/2026 BID AND PERMIT SET


Hard copy is intended to be 24"x36" when plotted. Scale(s) indicated and graphic quality may not be accurate for any other size.

SHEET NO.

©Copyright 2026
All Rights Reserve


©Copyright 2026
All Rights Reserve



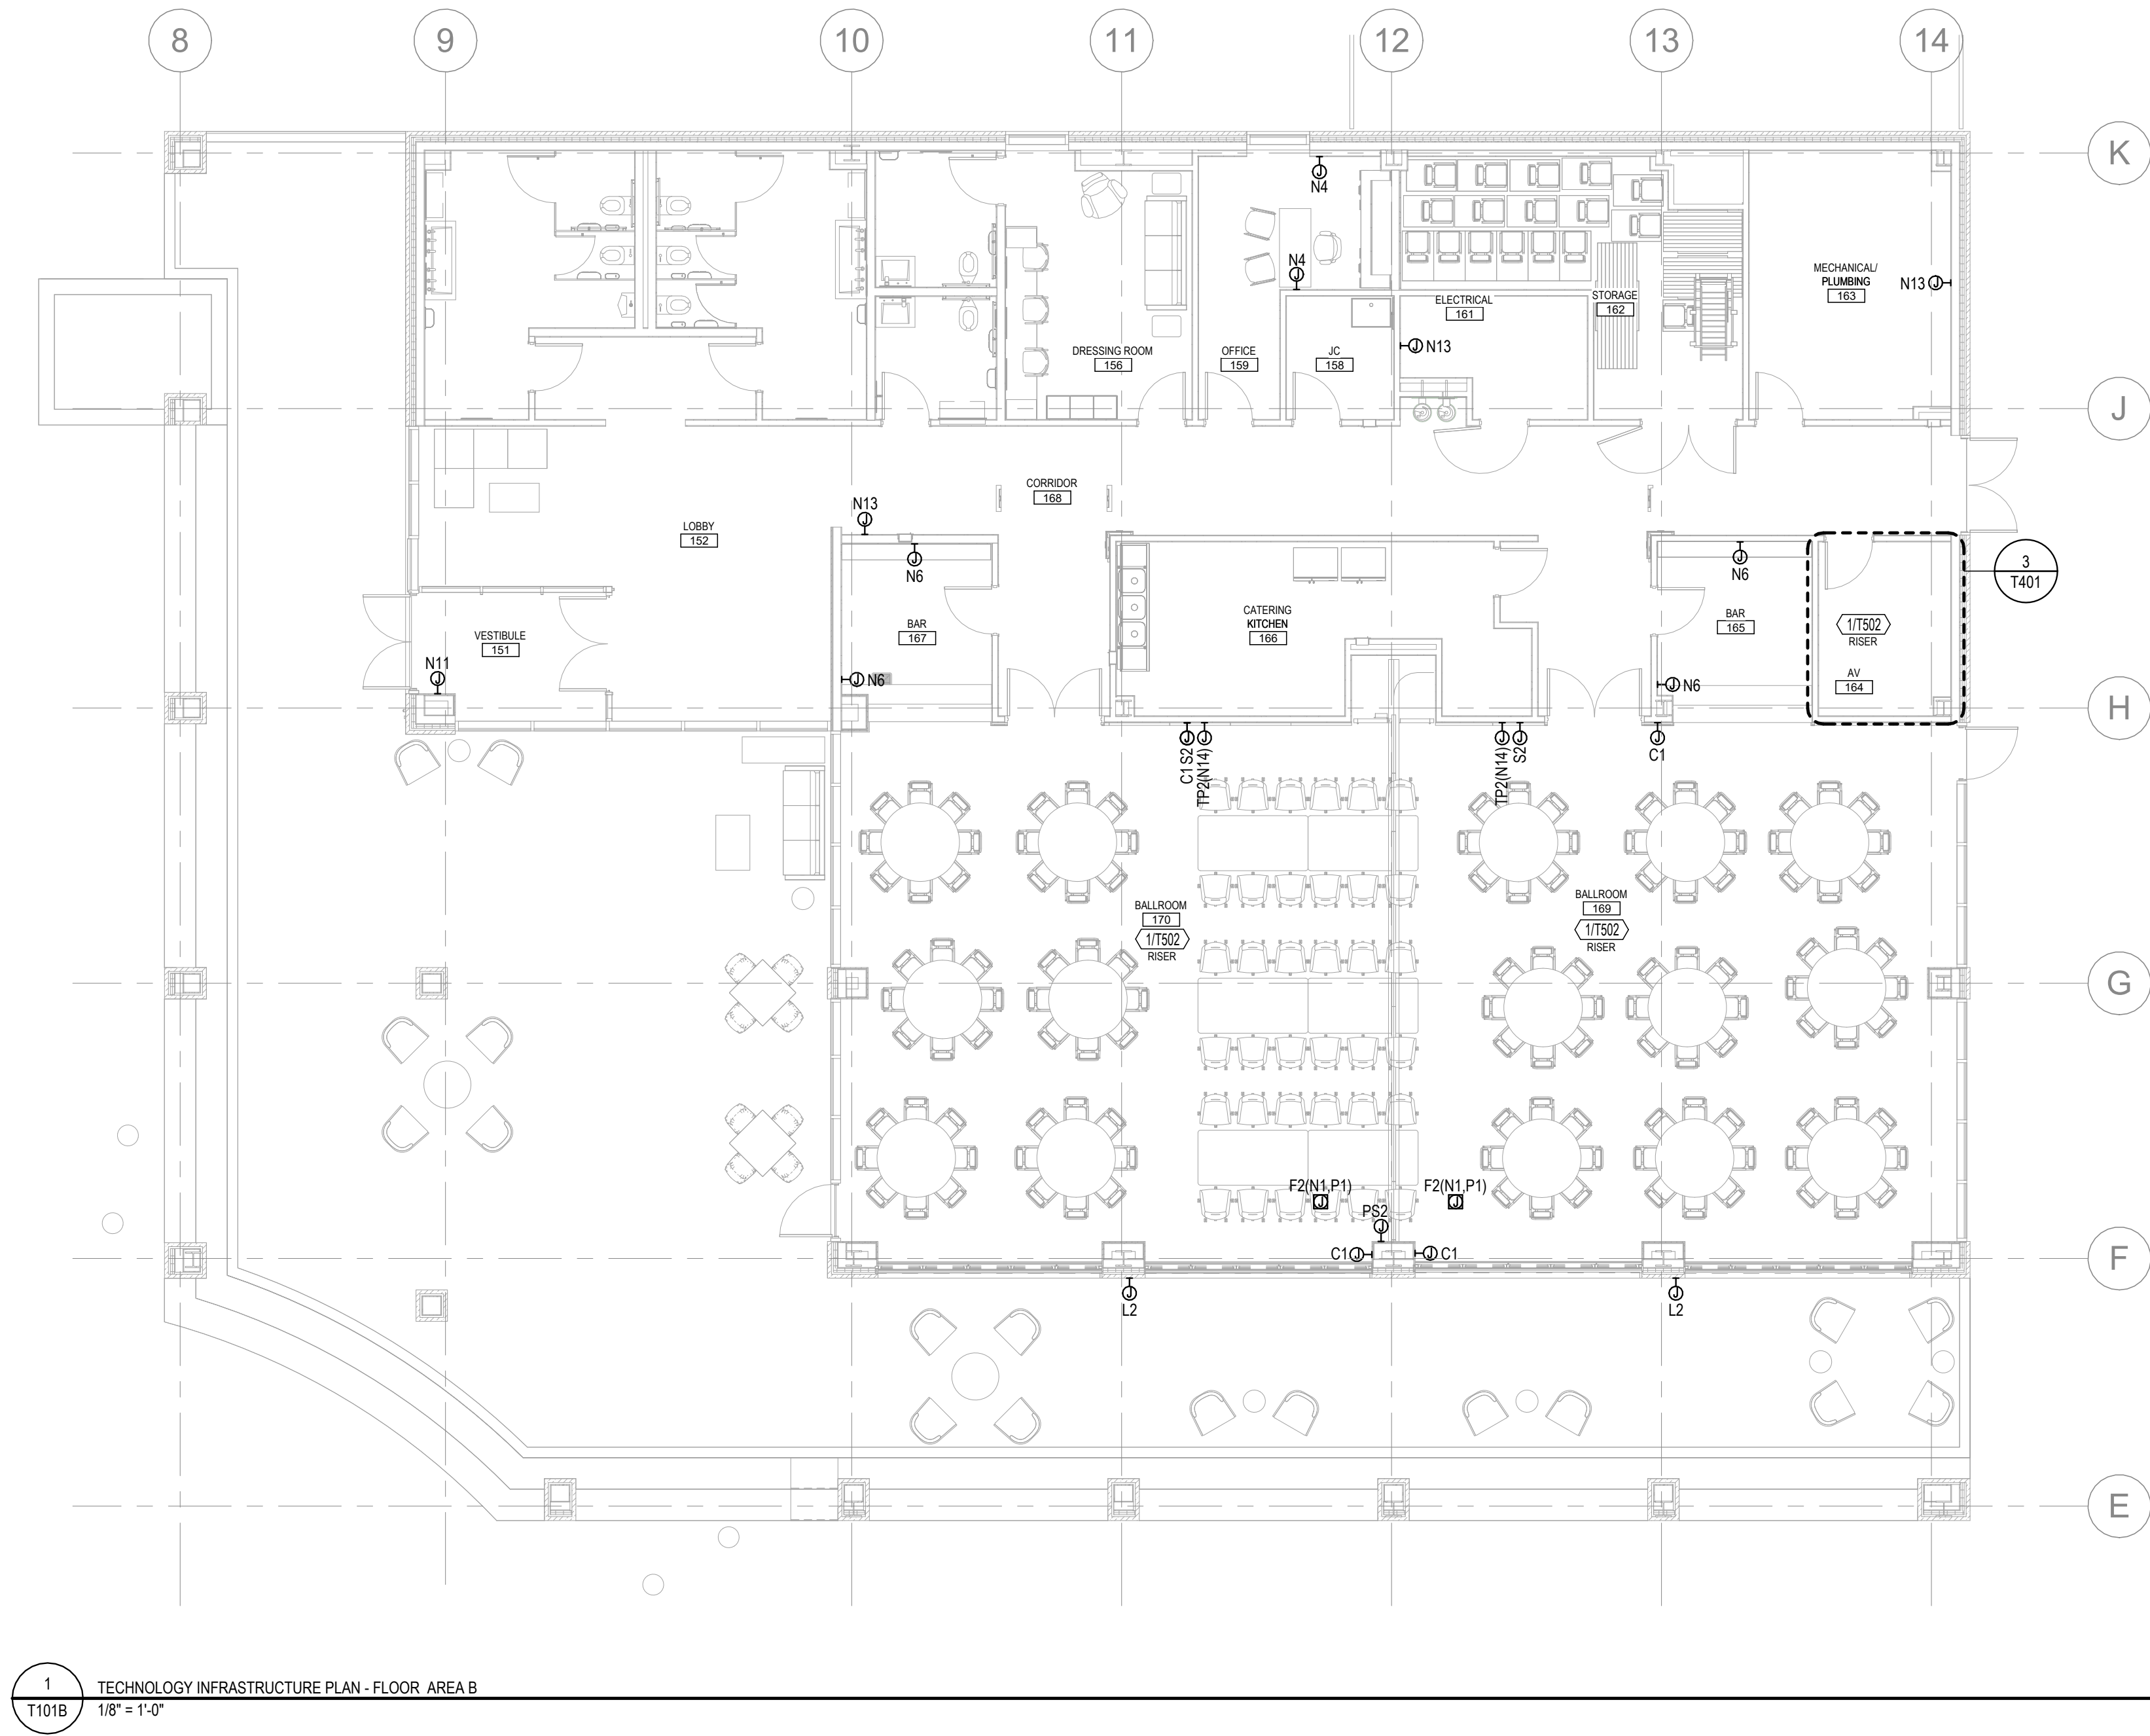

SHEET NOTES - INFRASTRUCTURE	
1	REFER TO SHEET T001 FOR ALL TECHNOLOGY INFRASTRUCTURE GENERAL NOTES, LEGENDS, ABBREVIATIONS, AND SHEET INDEX.
2	REFER TO SHEET T002 & T003 FOR ALL INFRASTRUCTURE SCHEDULES AND LEGENDS

KEY PLAN

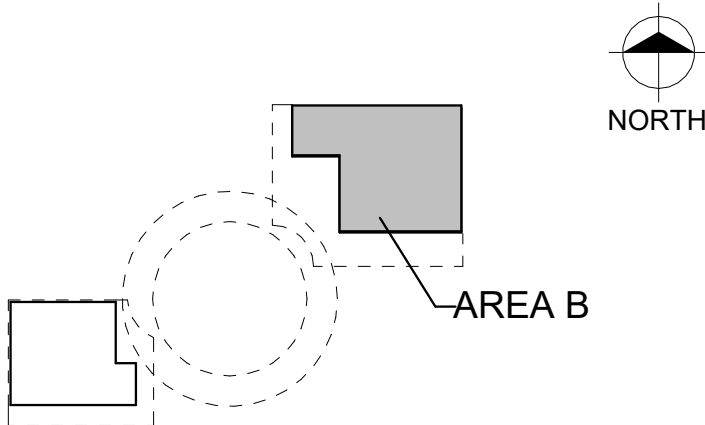

Van Buren Charter Township
Van Buren Township, MI
The Lakeside Park

REVISIONS

10/12/2026	BID AND PERMIT SET
Drawn By	TGAUNTNER
Designer	JFISHMAN, TROBINETTE
Reviewer	DCHITTY, KKERSTETTER
Manager	CKRETOVIC


Hard copy is intended to be 24"x36" when plotted. Scale(s) indicated and graphic quality may not be accurate for any other size.

PROJECT NO.
2500281
SHEET NO.

T101B

PLOT INFO: 10/2/2026 10:52:08 AM Autodesk Docs://2500281 - Van Buren Twp Lake House2026_T_2500281.rvt


1 TECHNOLOGY INFRASTRUCTURE REFLECTED CEILING PLAN - FLOOR AREA A
T201A 1/8" = 1'-0"

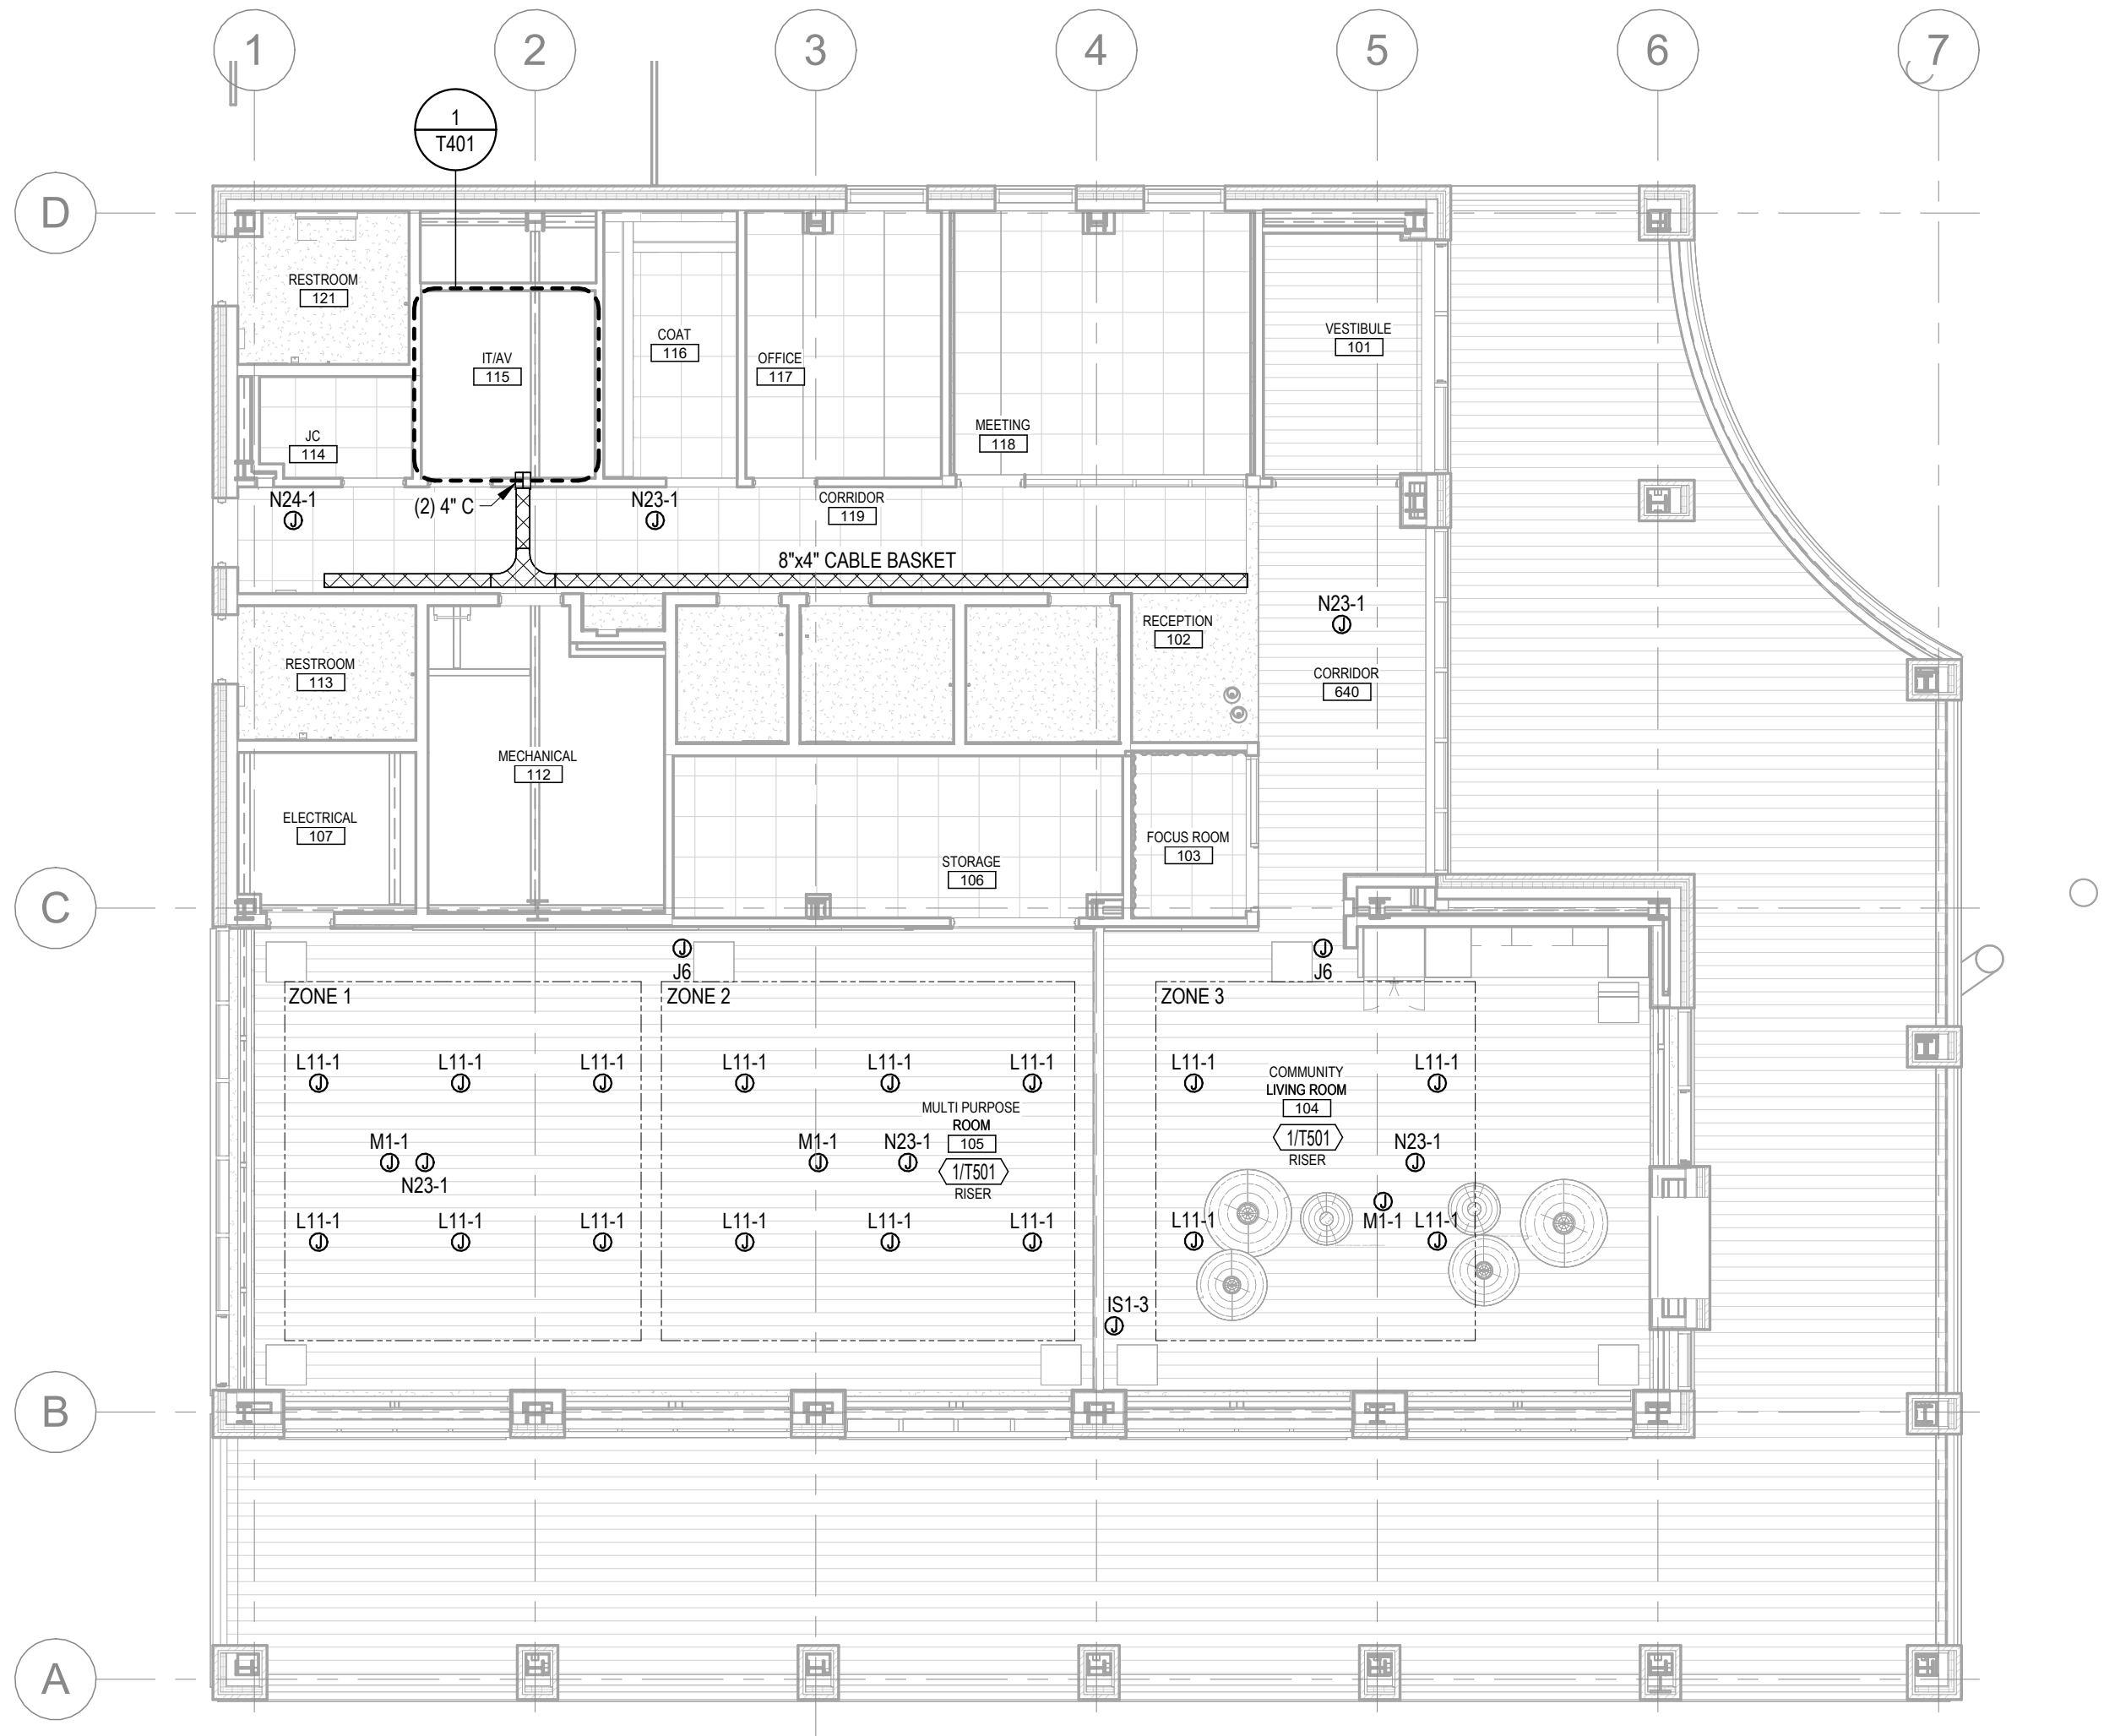

SHEET NOTES - INFRA RCP

- REFER TO SHEET T001 FOR ALL TECHNOLOGY INFRASTRUCTURE GENERAL NOTES, LEGENDS, ABBREVIATIONS, AND SHEET INDEX.
- REFER TO SHEET T002 & T003 FOR ALL INFRASTRUCTURE SCHEDULES AND LEGENDS

KEY PLAN

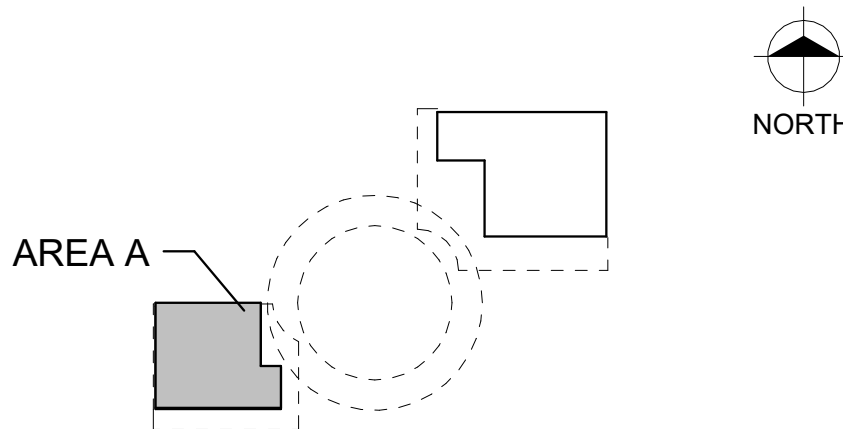

Van Buren Charter Township

Van Buren Township, MI

The Lakeside Park

REVISIONS

10/12/2026 BID AND PERMIT SET

Drawn By TGAUNTNER
Designer JFISHMAN, TROBINETTE
Reviewer DCHITTY, KKERSTETTER
Manager CKRETOVIC


Hard copy is intended to be 24"x36" when plotted. Scale(s) indicated and graphic quality may not be accurate for any other size.

PROJECT NO.
2500281

SHEET NO.


T201A

©Copyright 2026
All Rights Reserved

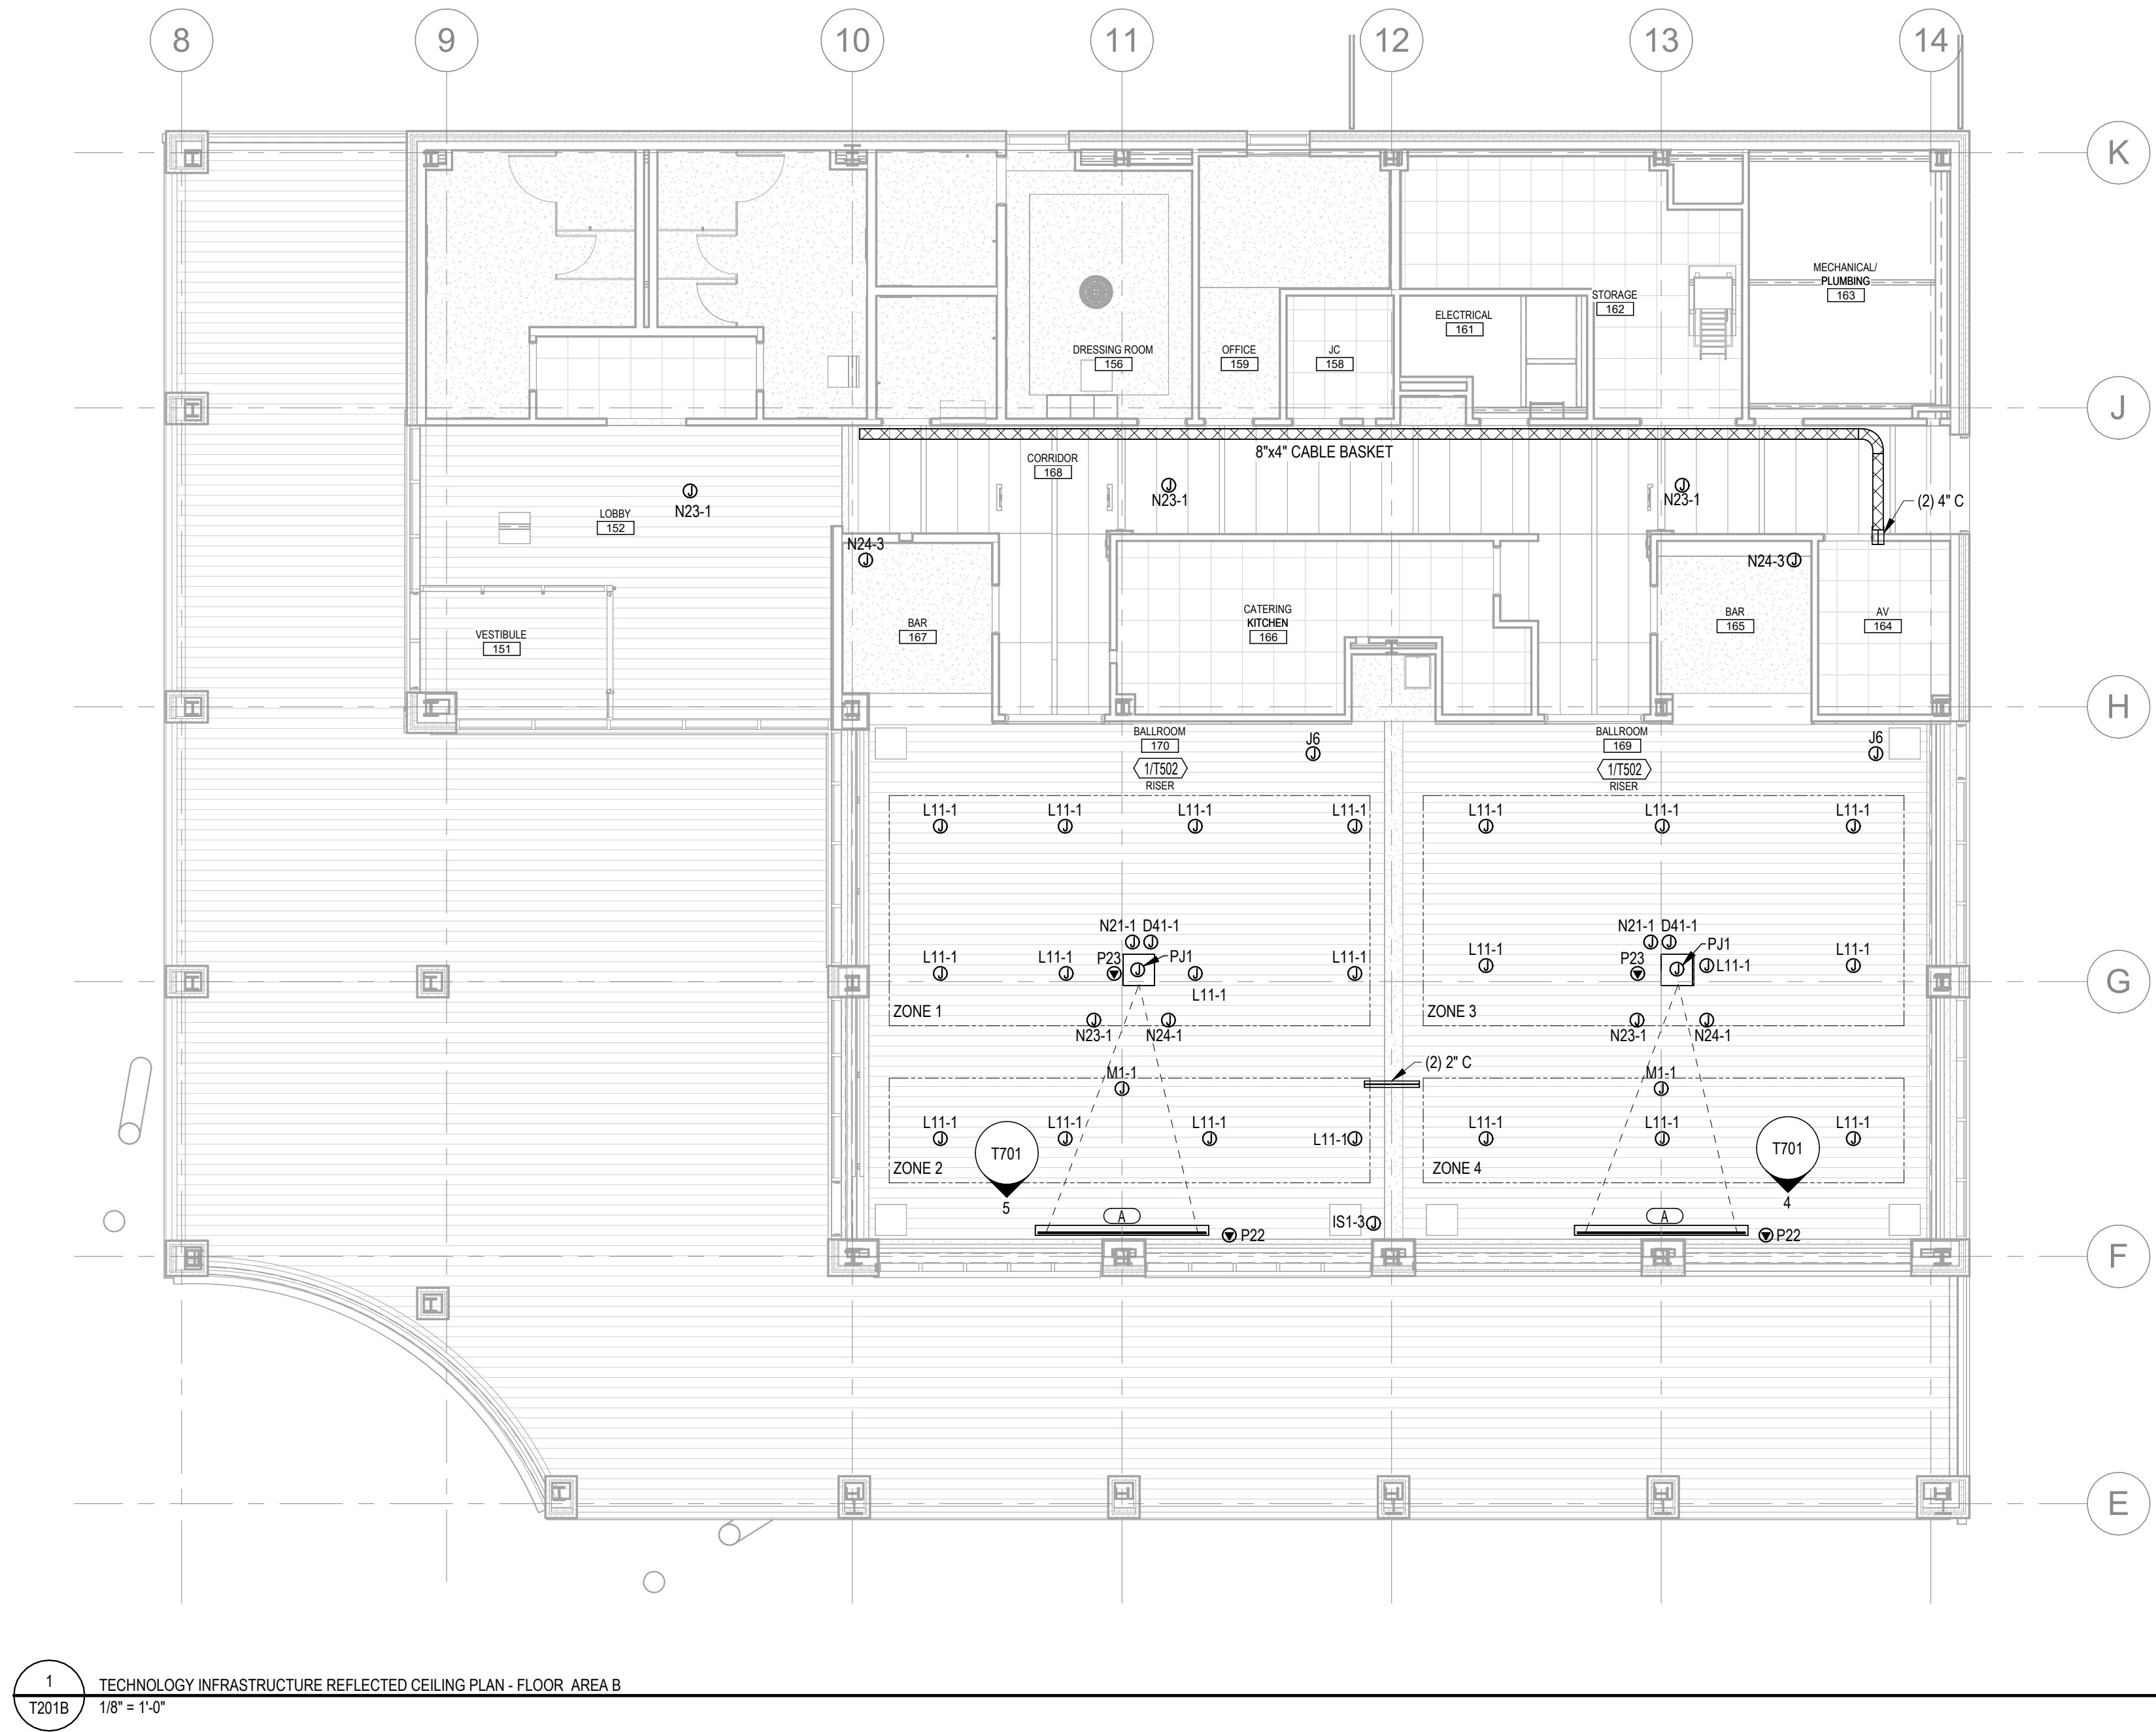

SHEET NOTES - INFRA RCP	
1	REFER TO SHEET T001 FOR ALL TECHNOLOGY INFRASTRUCTURE GENERAL NOTES, LEGENDS, ABBREVIATIONS, AND SHEET INDEX.
2	REFER TO SHEET T002 & T003 FOR ALL INFRASTRUCTURE SCHEDULES AND LEGENDS

KEY PLAN

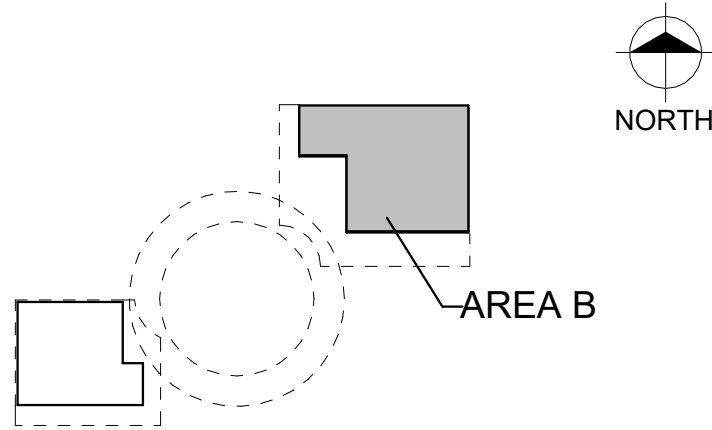

Van Buren Charter Township
Van Buren Township, MI
The Lakeside Park

REVISIONS


10/12/2026	BID AND PERMIT SET
Drawn By	TGAUNTNER
Designer	JFISHMAN, TROBINETTE
Reviewer	DCHITTY, KKERSTETTER
Manager	CKRETOVIC

Hard copy is intended to be 24"x36" when plotted. Scale(s) indicated and graphic quality may not be accurate for any other size.

PROJECT NO.
2500281
SHEET NO.

T201B


©Copyright 2026
All Rights Reserved

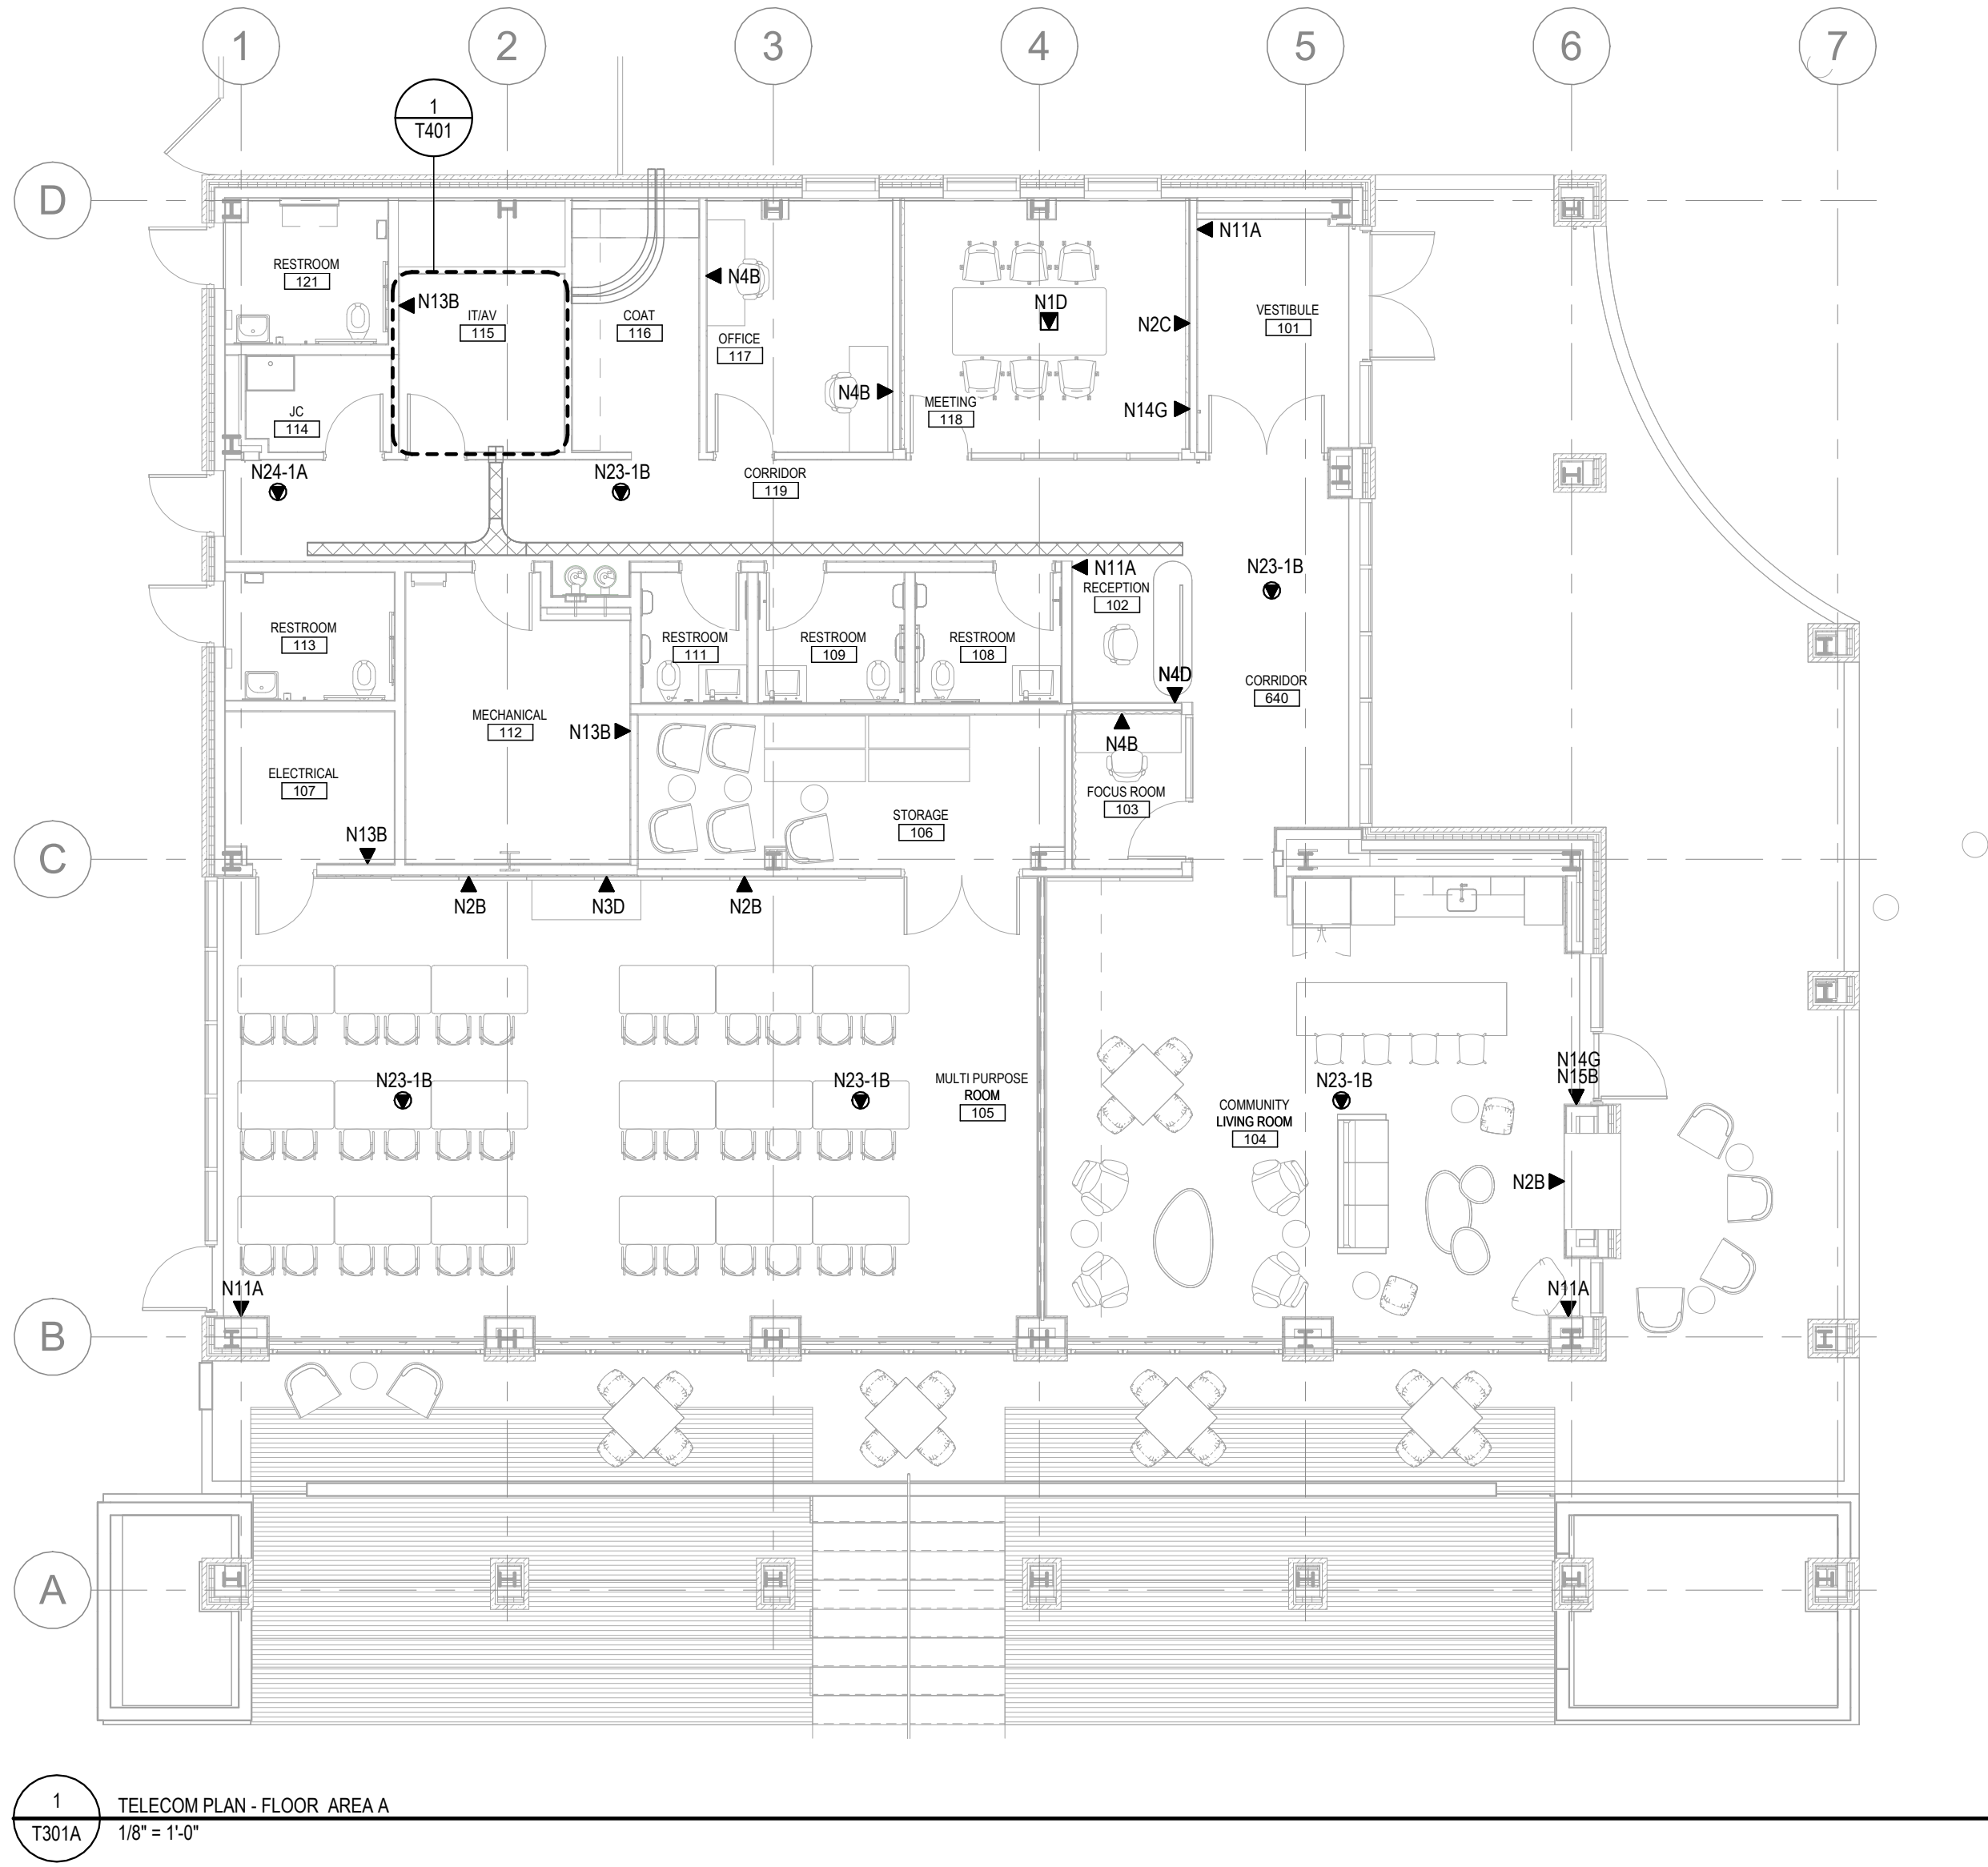

1
T301A TELECOM PLAN - FLOOR AREA A
1/8" = 1'-0"

SHEET NOTES - TELECOM					
1	REFER TO SHEET T001 FOR ALL TELECOM GENERAL NOTES, LEGENDS, ABBREVIATIONS, AND SHEET INDEX.				
2	REFER TO SHEET T002 & T003 FOR ALL TELECOM SCHEDULES AND LEGENDS				
TELECOM CABLING LEGEND					
TYPE	CAT6A	FIBER	COAX	REFERENCE DETAIL	NOTES
A	1	0	0	1/T901	-
B	2	0	0	1/T901	-
C	3	0	0	1/T901	-
D	4	0	0	1/T901	-
E	6	0	0	1/T901	-
G	1	0	0	1/T901	DIRECT CONNECT

KEY PLAN

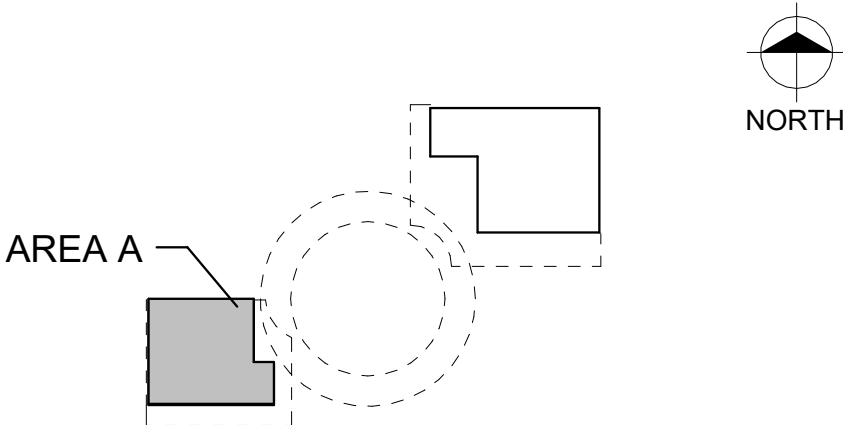

Van Buren Charter Township
Van Buren Township, MI
The Lakeside Park


REVISIONS

10/12/2026	BID AND PERMIT SET
Drawn By	TGAUNTNER
Designer	JFISHMAN, TROBINETTE
Reviewer	DCHITTY, KKERSTETTER
Manager	CKRETOVIC


Hard copy is intended to be 24"x36" when plotted. Scale(s) indicated and graphic quality may not be accurate for any other size.

PROJECT NO.
2500281
SHEET NO.


T301A

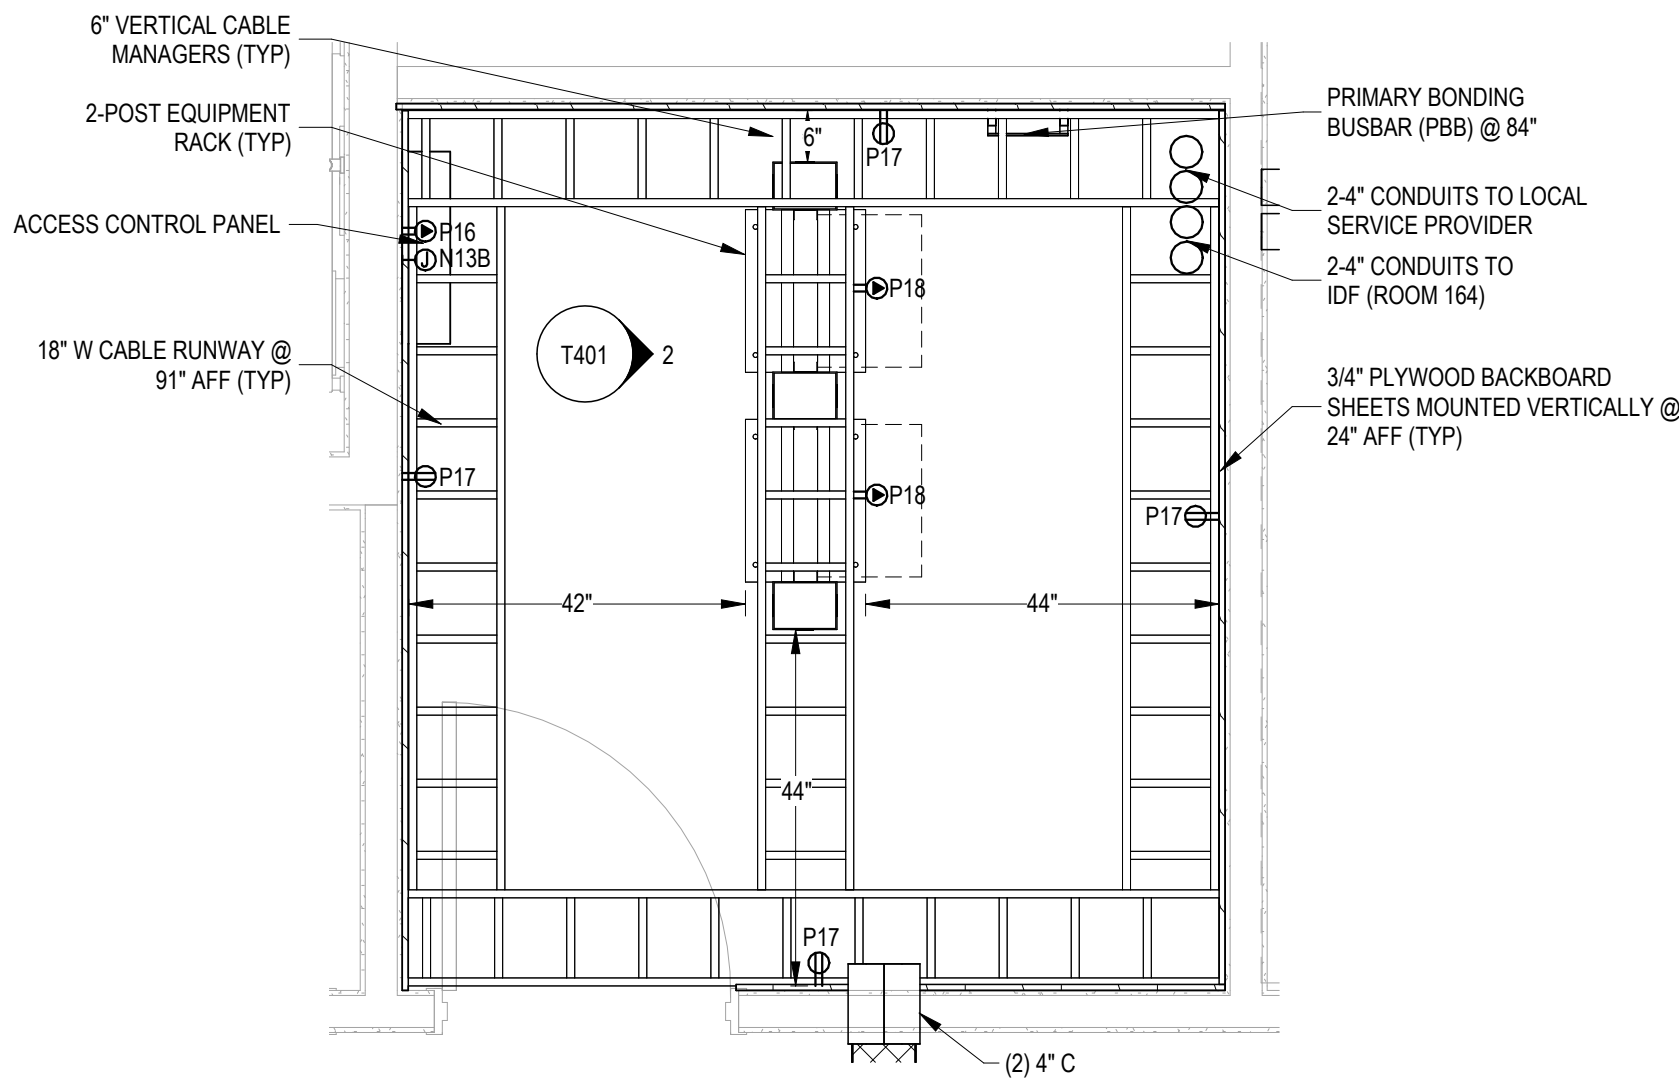


1
T401
IT/AV 115 ENLARGED PLAN
1/2" = 1'-0"

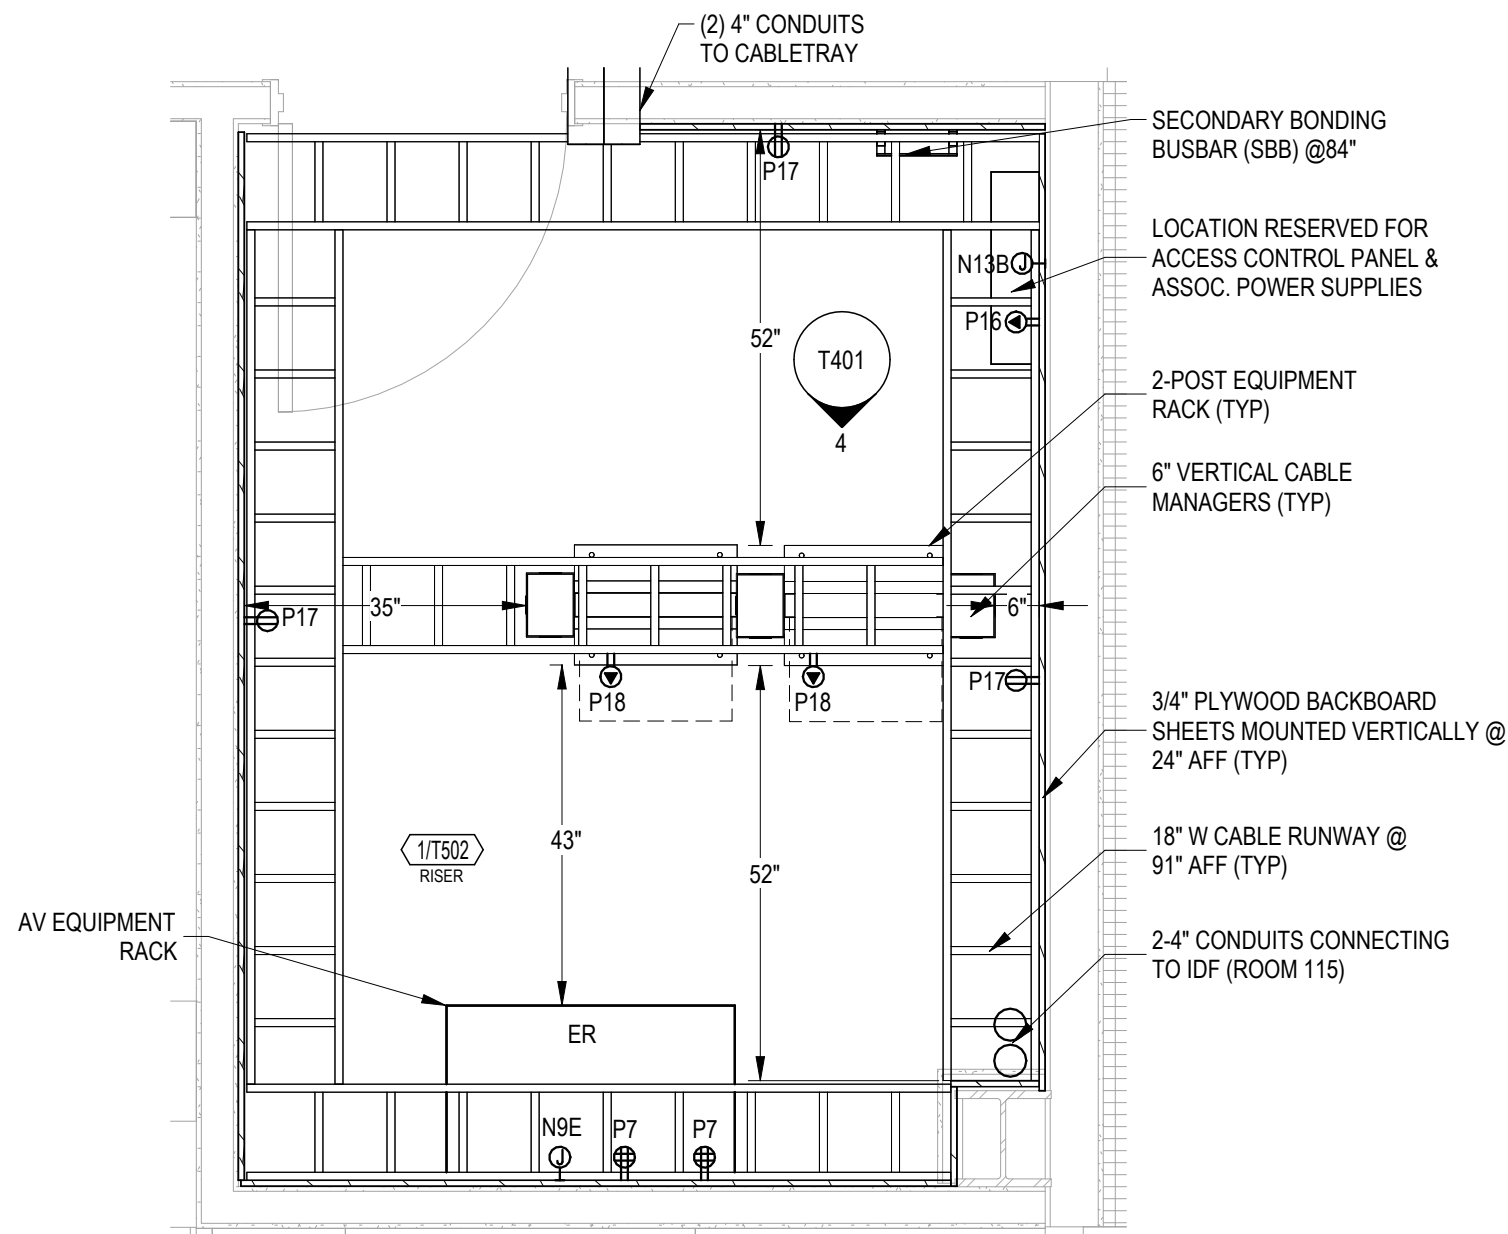

3
T401
AV 164 ENLARGED PLAN
1/2" = 1'-0"

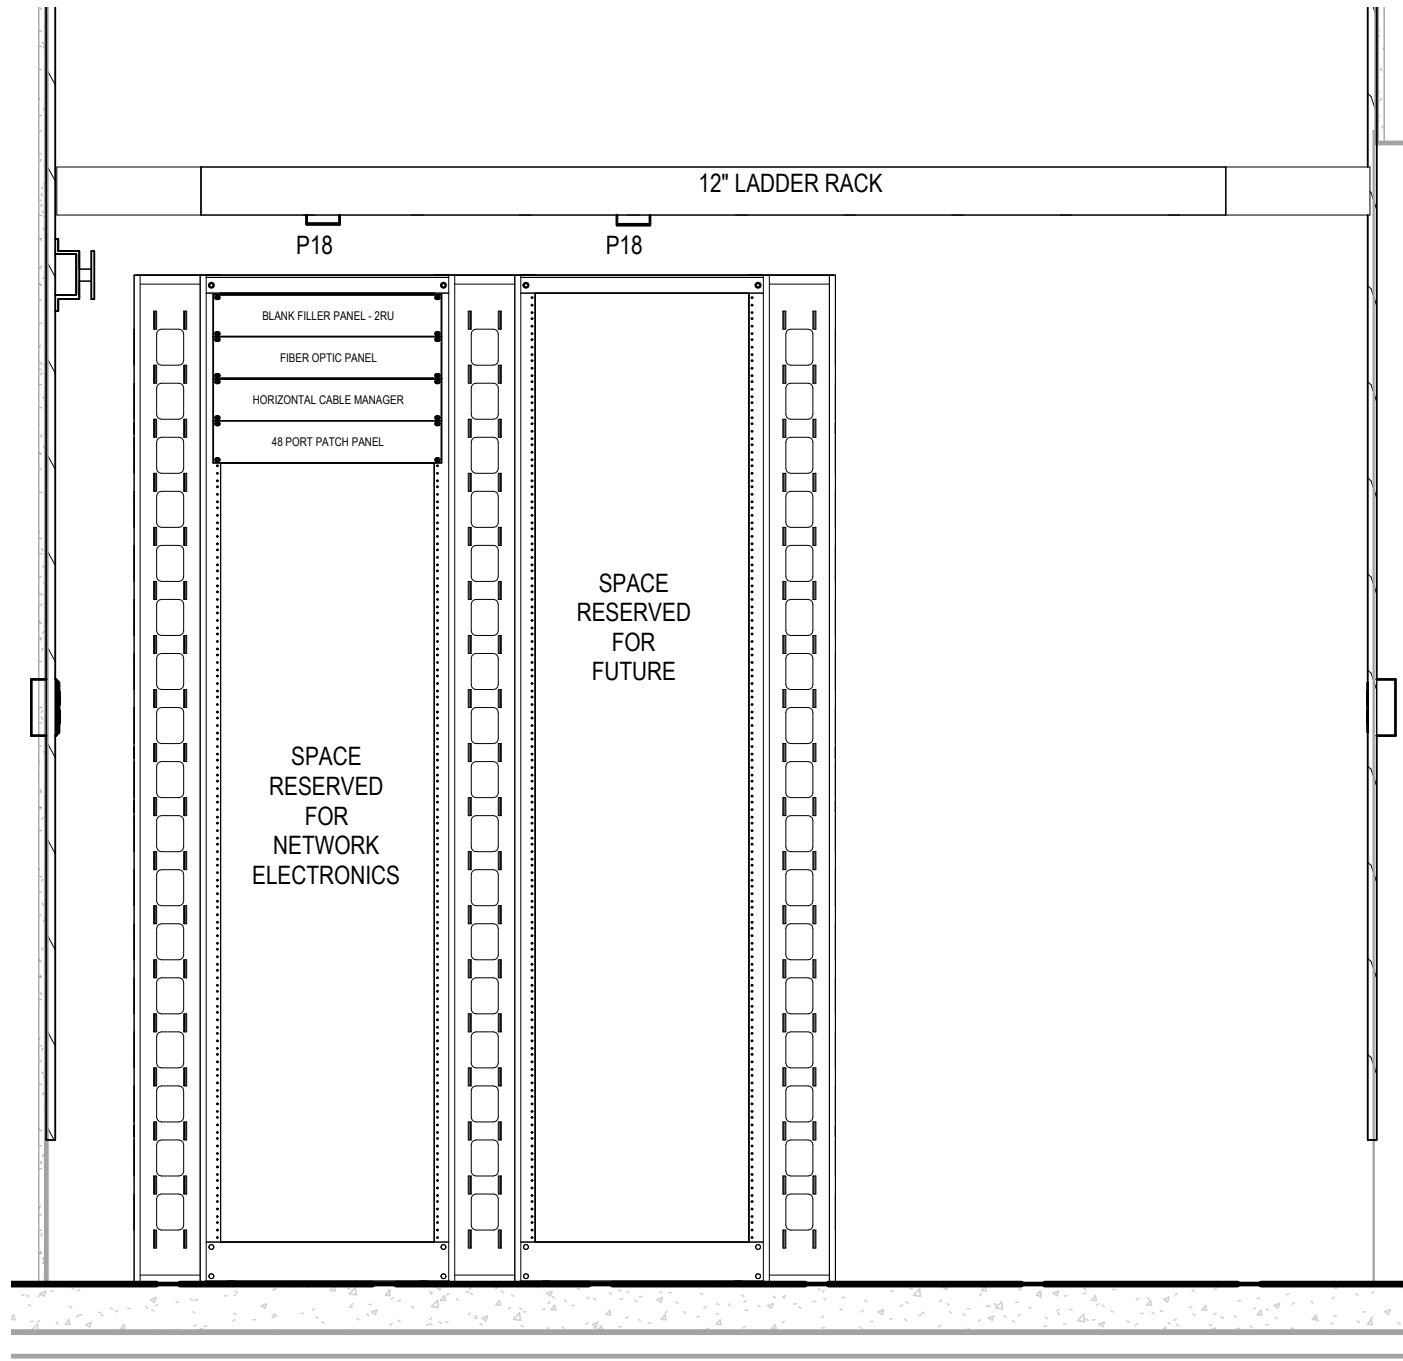

2
T401
IT/AV RACK ELEVATION
3/4" = 1'-0"

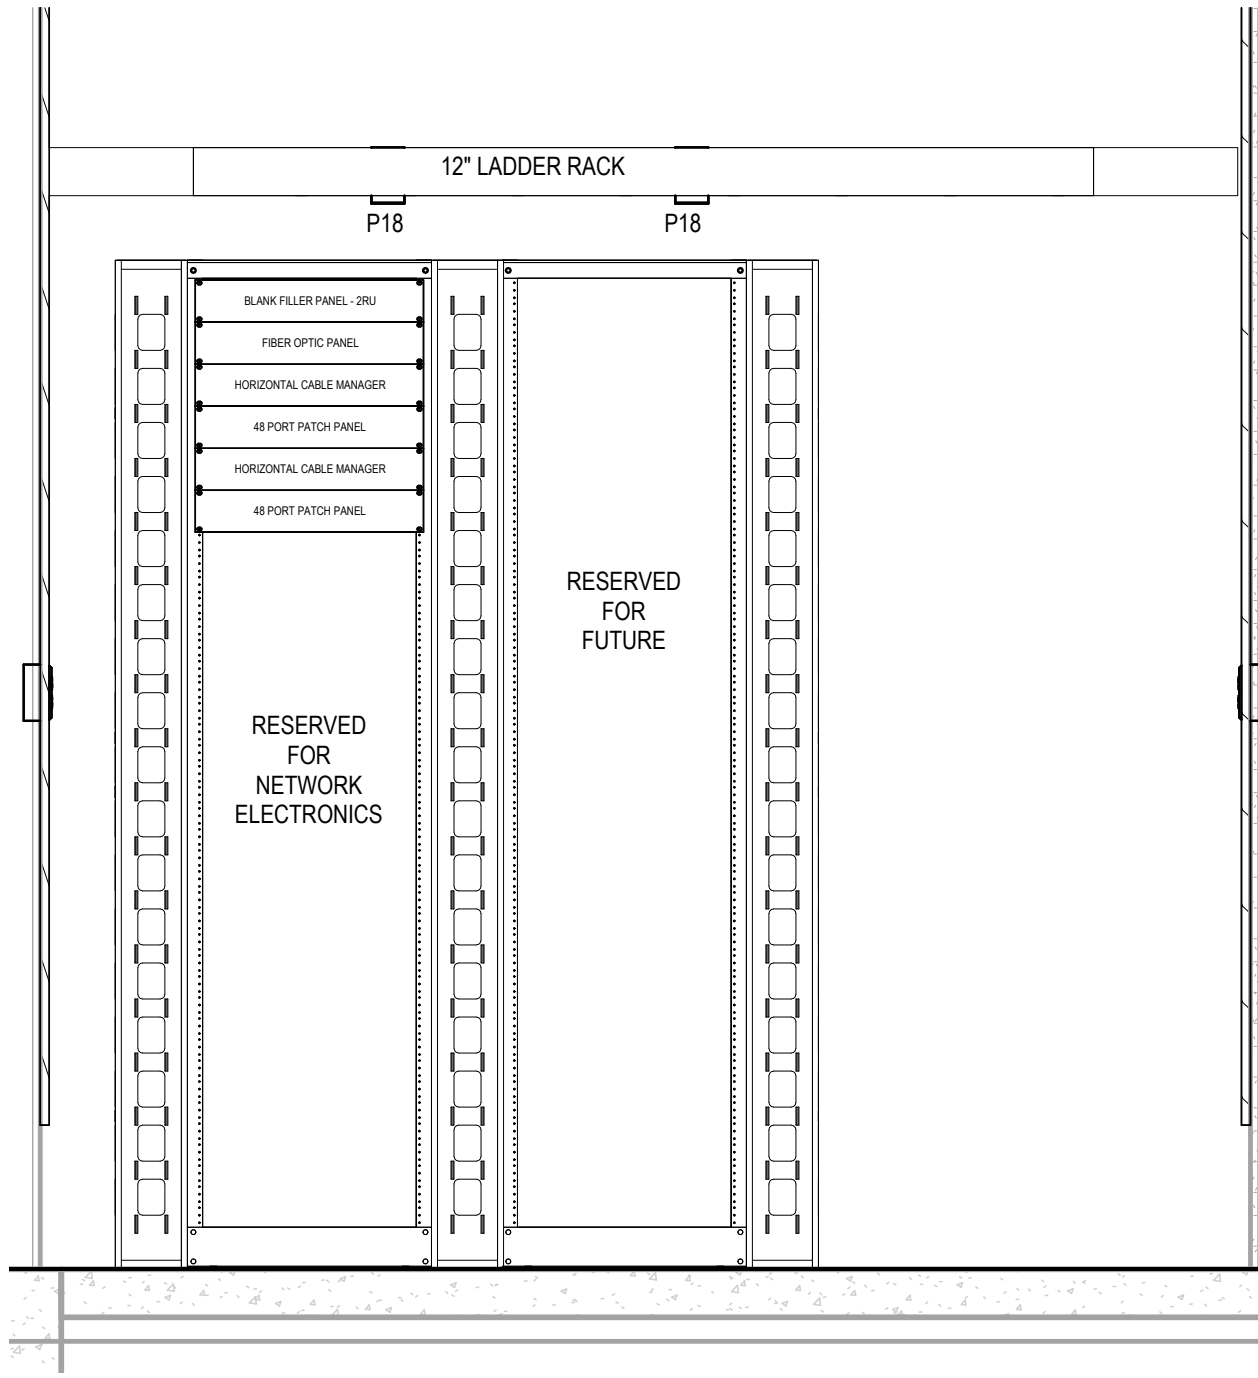

4
T401
AV 164 RACK ELEVATION
3/4" = 1'-0"

Van Buren Charter Township
Van Buren Township, MI
The Lakeside Park

REVISIONS

10/12/2026 BID AND PERMIT SET

Drawn By TGAUNTNER
Designer JFISHMAN,
TROBINETTE
Reviewer DCHITTY
KKERSTETTER
Manager CKRETOVIC


Hard copy is intended to be 24"x36" when plotted. Scale(s) indicated and graphic quality may not be accurate for any other size.

PROJECT NO.
2500281

SHEET NO.

T401

PLOT INFO: 10/2/2026 10:52:18 AM Autodesk Docs://2500281 - Van Buren Twp Lake House2026_T_2500281.rvt

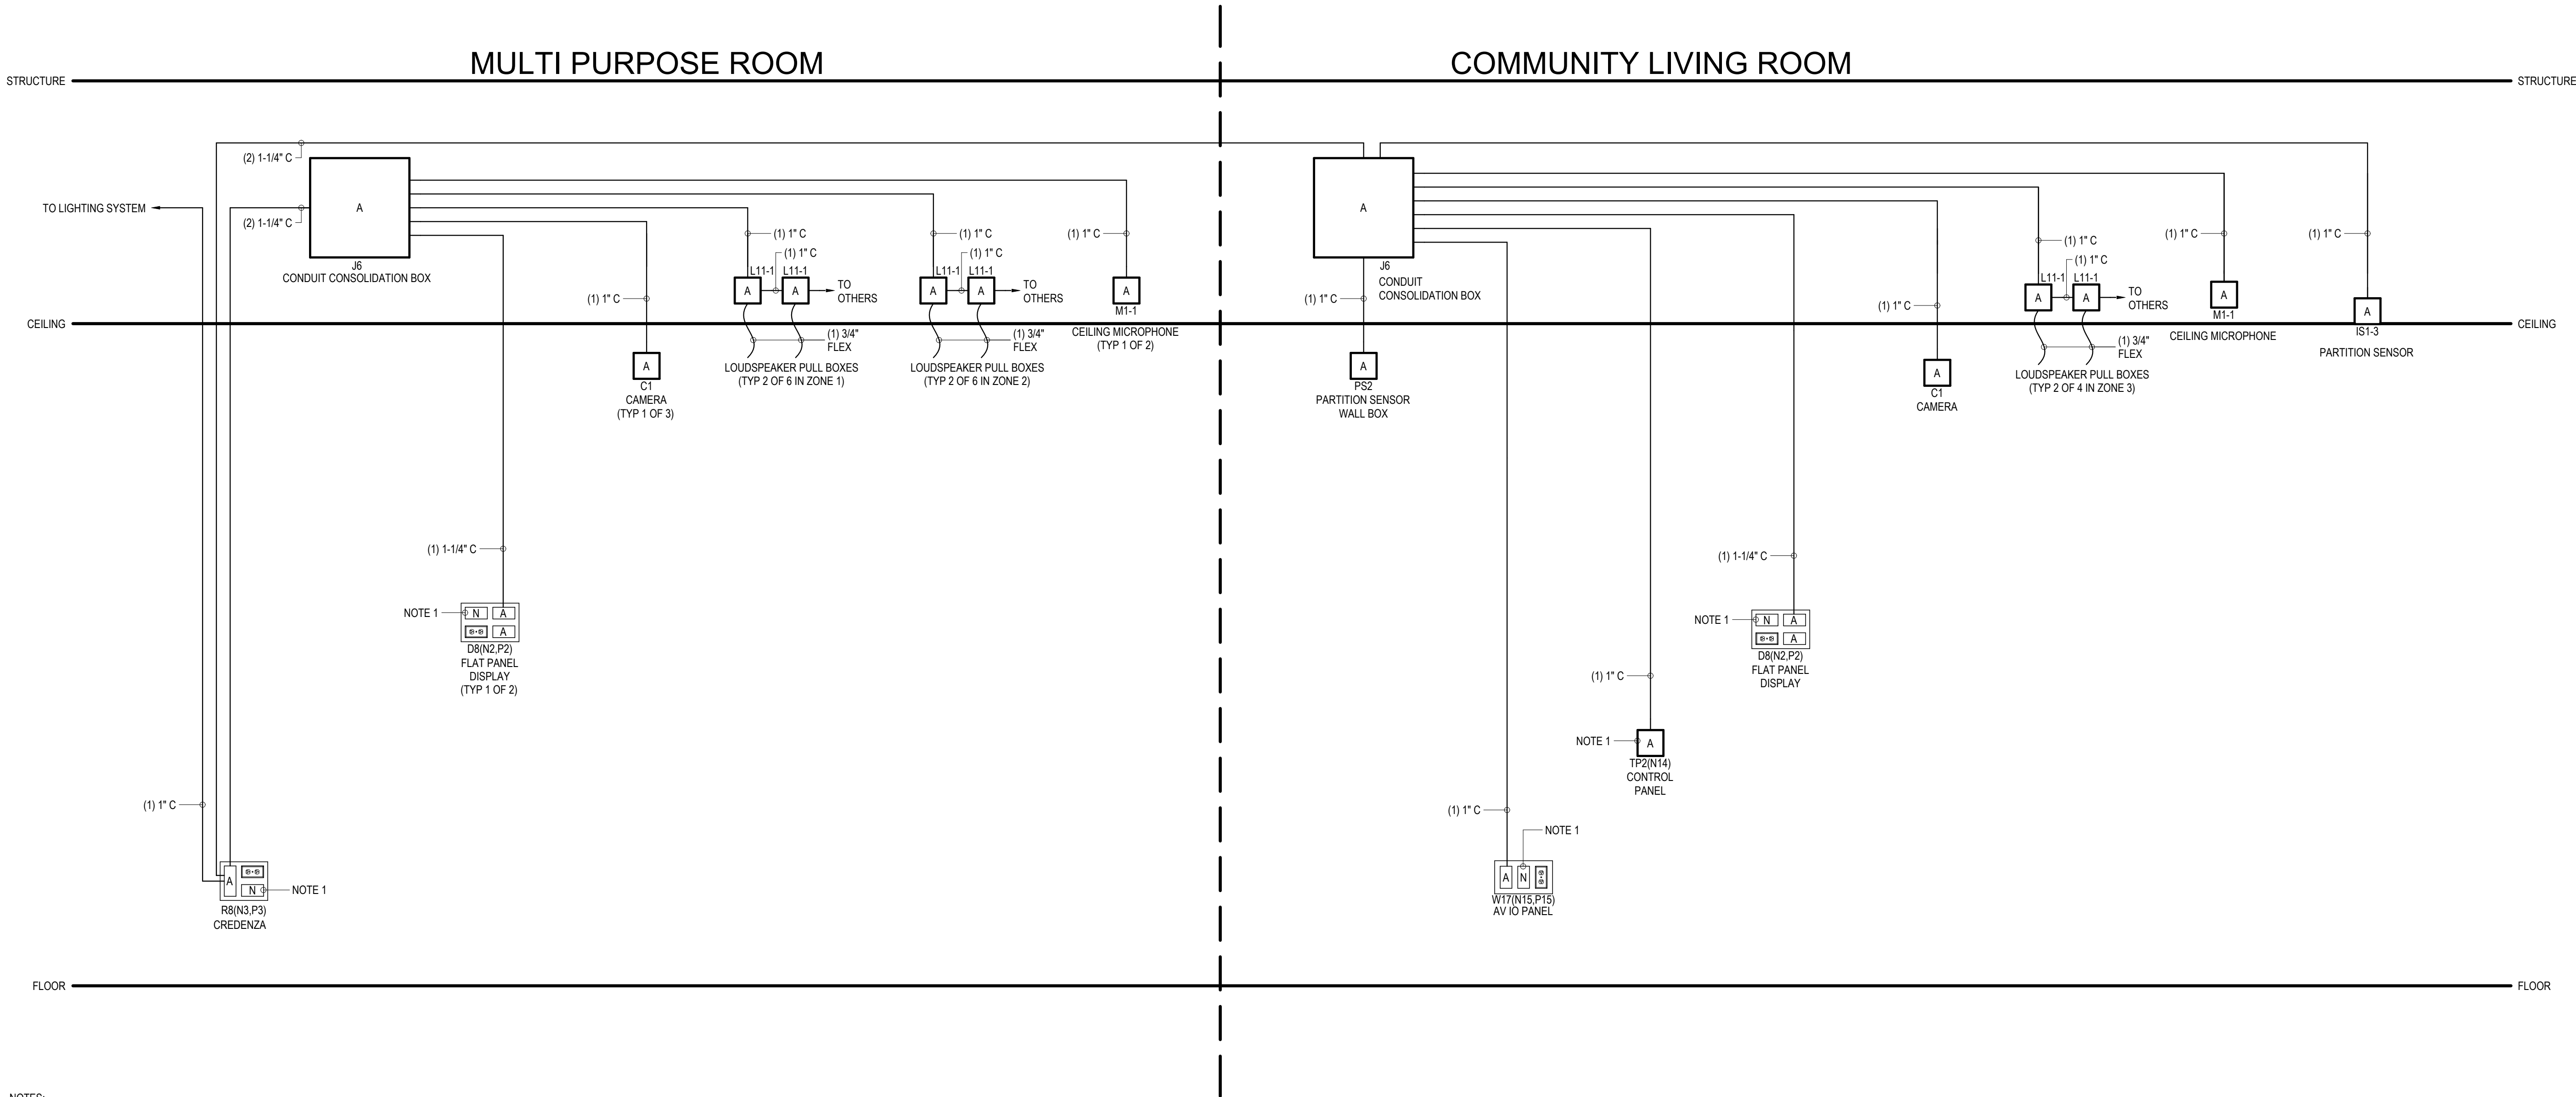

- NOTES:
- JUNCTION BOXES THAT ARE SHARED BY AV AND TELECOM, REFER TO TELECOM RISER DIAGRAM FOR ASSOCIATED CONDUIT SIZE AND PATHWAY REQUIREMENTS.

1
T501 MULTI PURPOSE ROOM / COMMUNITY LIVING ROOM
NTS

Van Buren Charter Township
Van Buren Township, MI
The Lakeside Park

REVISIONS

10/12/2026 BID AND PERMIT SET	
Drawn By	TGAUNTNER
Designer	JFISHMAN, TROBINETTE
Reviewer	DCHITTY, KKERSTETTER
Manager	CKRETOVIC


Hard copy is intended to be 24"x36" when plotted. Scale(s) indicated and graphic quality may not be accurate for any other size.

PROJECT NO.
2500281
SHEET NO.

T501

©Copyright 2026
All Rights Reserved

PLOT INFO: 10/2/2026 10:52:19 AM Autodesk Docs://2500281 - Van Buren Twp Lake House2026_T_2500281.rvt

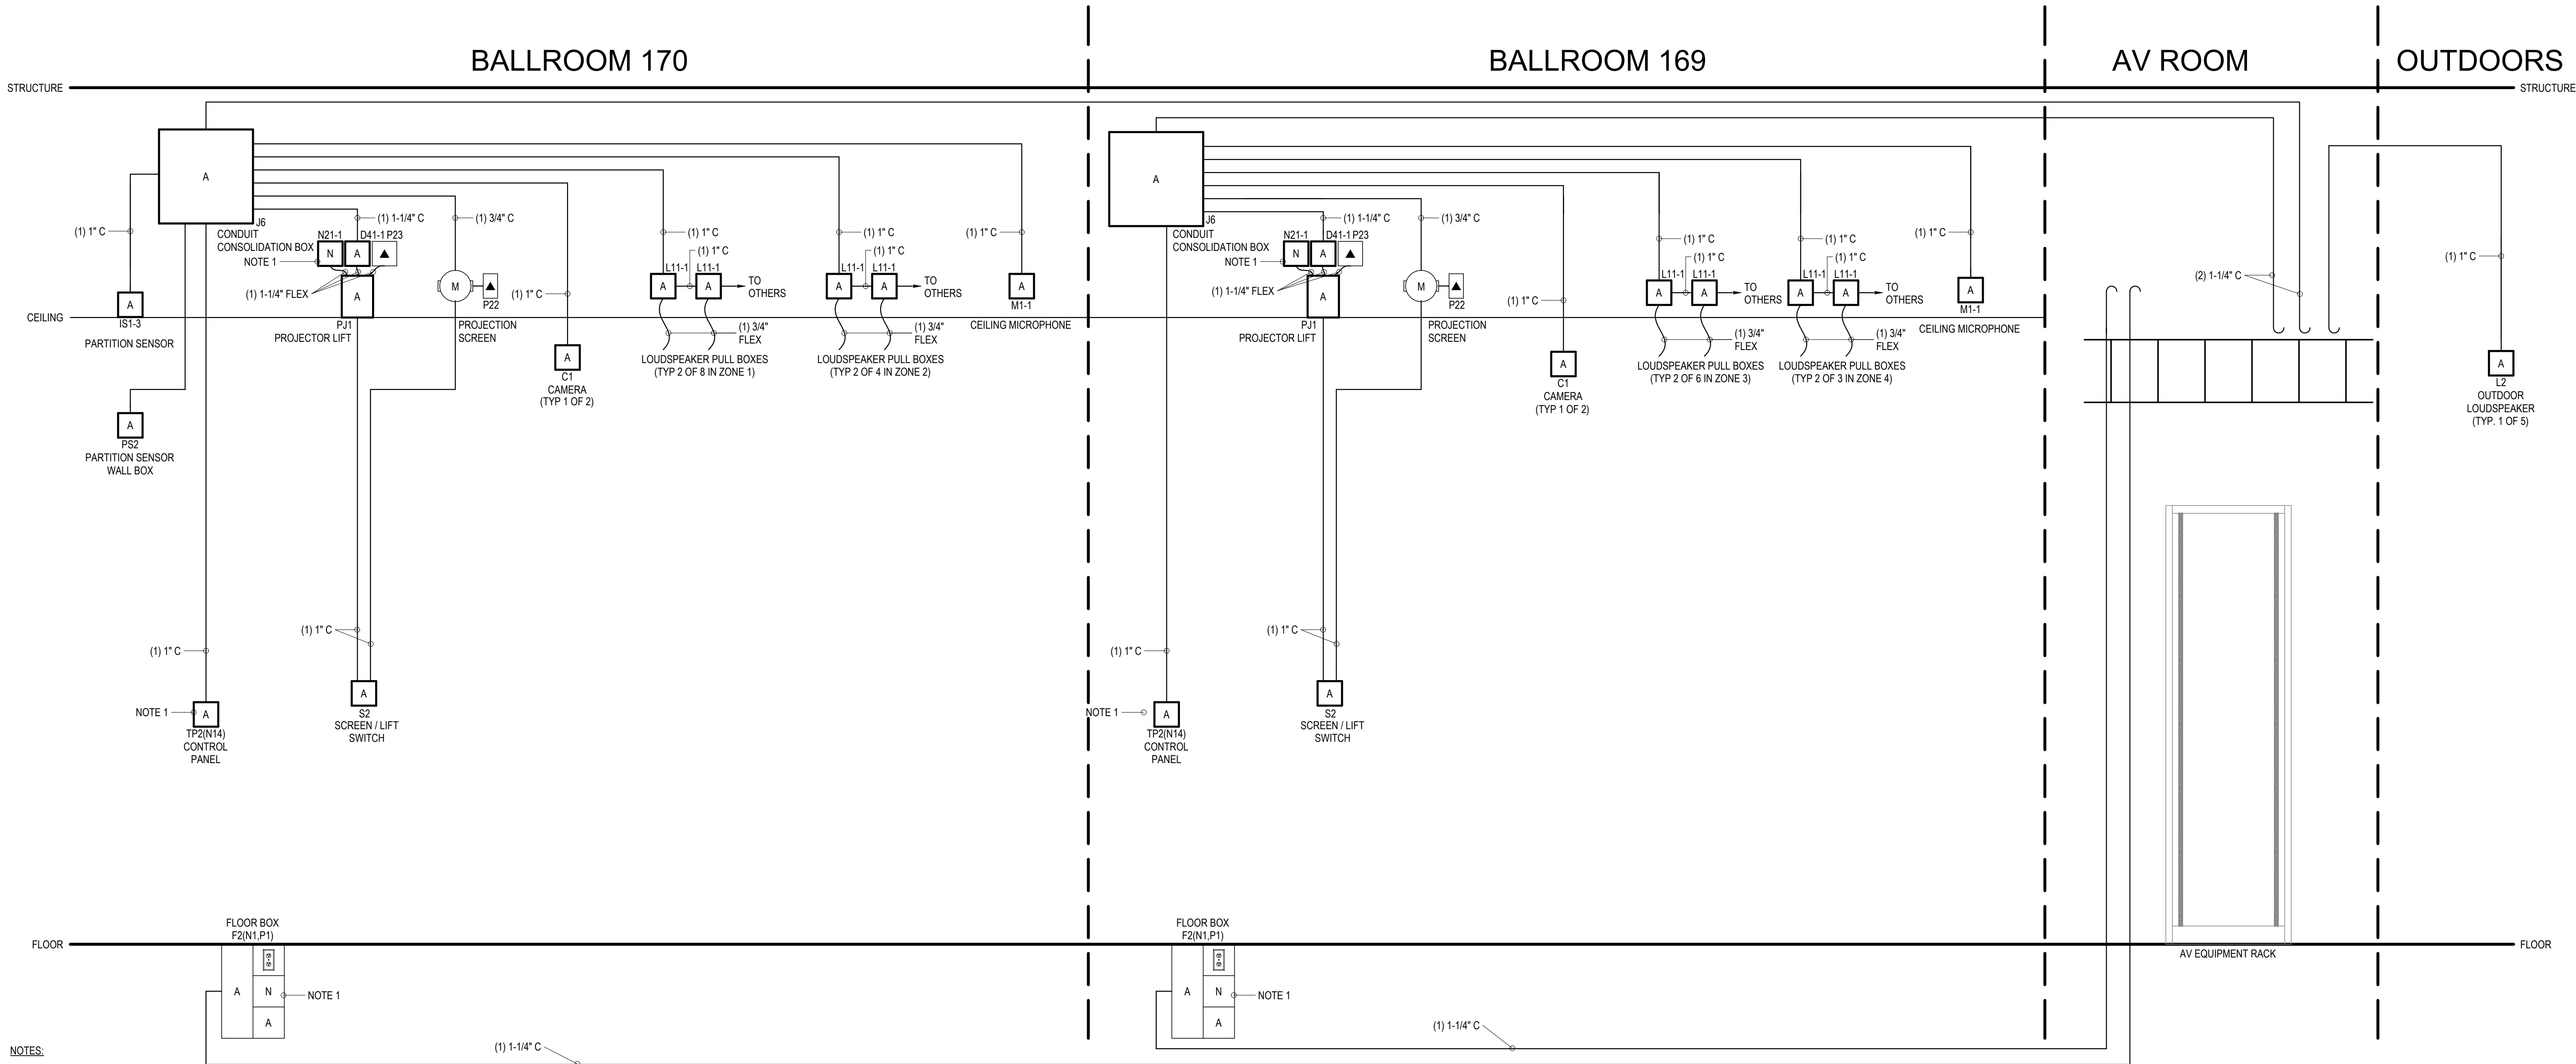

NOTES:

1. JUNCTION BOXES THAT ARE SHARED BY AV AND TELECOM, REFER TO TELECOM RISER DIAGRAM FOR ASSOCIATED CONDUIT SIZE AND PATHWAY REQUIREMENTS.

REVISIONS

10/12/2026 BID AND PERMIT SET

Drawn By TGAUNTNER
Designer JFISHMAN,
Reviewer TROBINETTE,
Manager DCHITTY,
KKERSTETTER
CKRETOVIC


Hard copy is intended to be 24"x36" when plotted. Scale(s) indicated and graphic quality may not be accurate for any other size.

PROJECT NO.
2500281


SHEET NO.

T502

PLOT INFO: 10/2/2026 10:52:19 AM Autodesk Docs://2500281 - Van Buren Twp Lake House2026_T_2500281.rvt

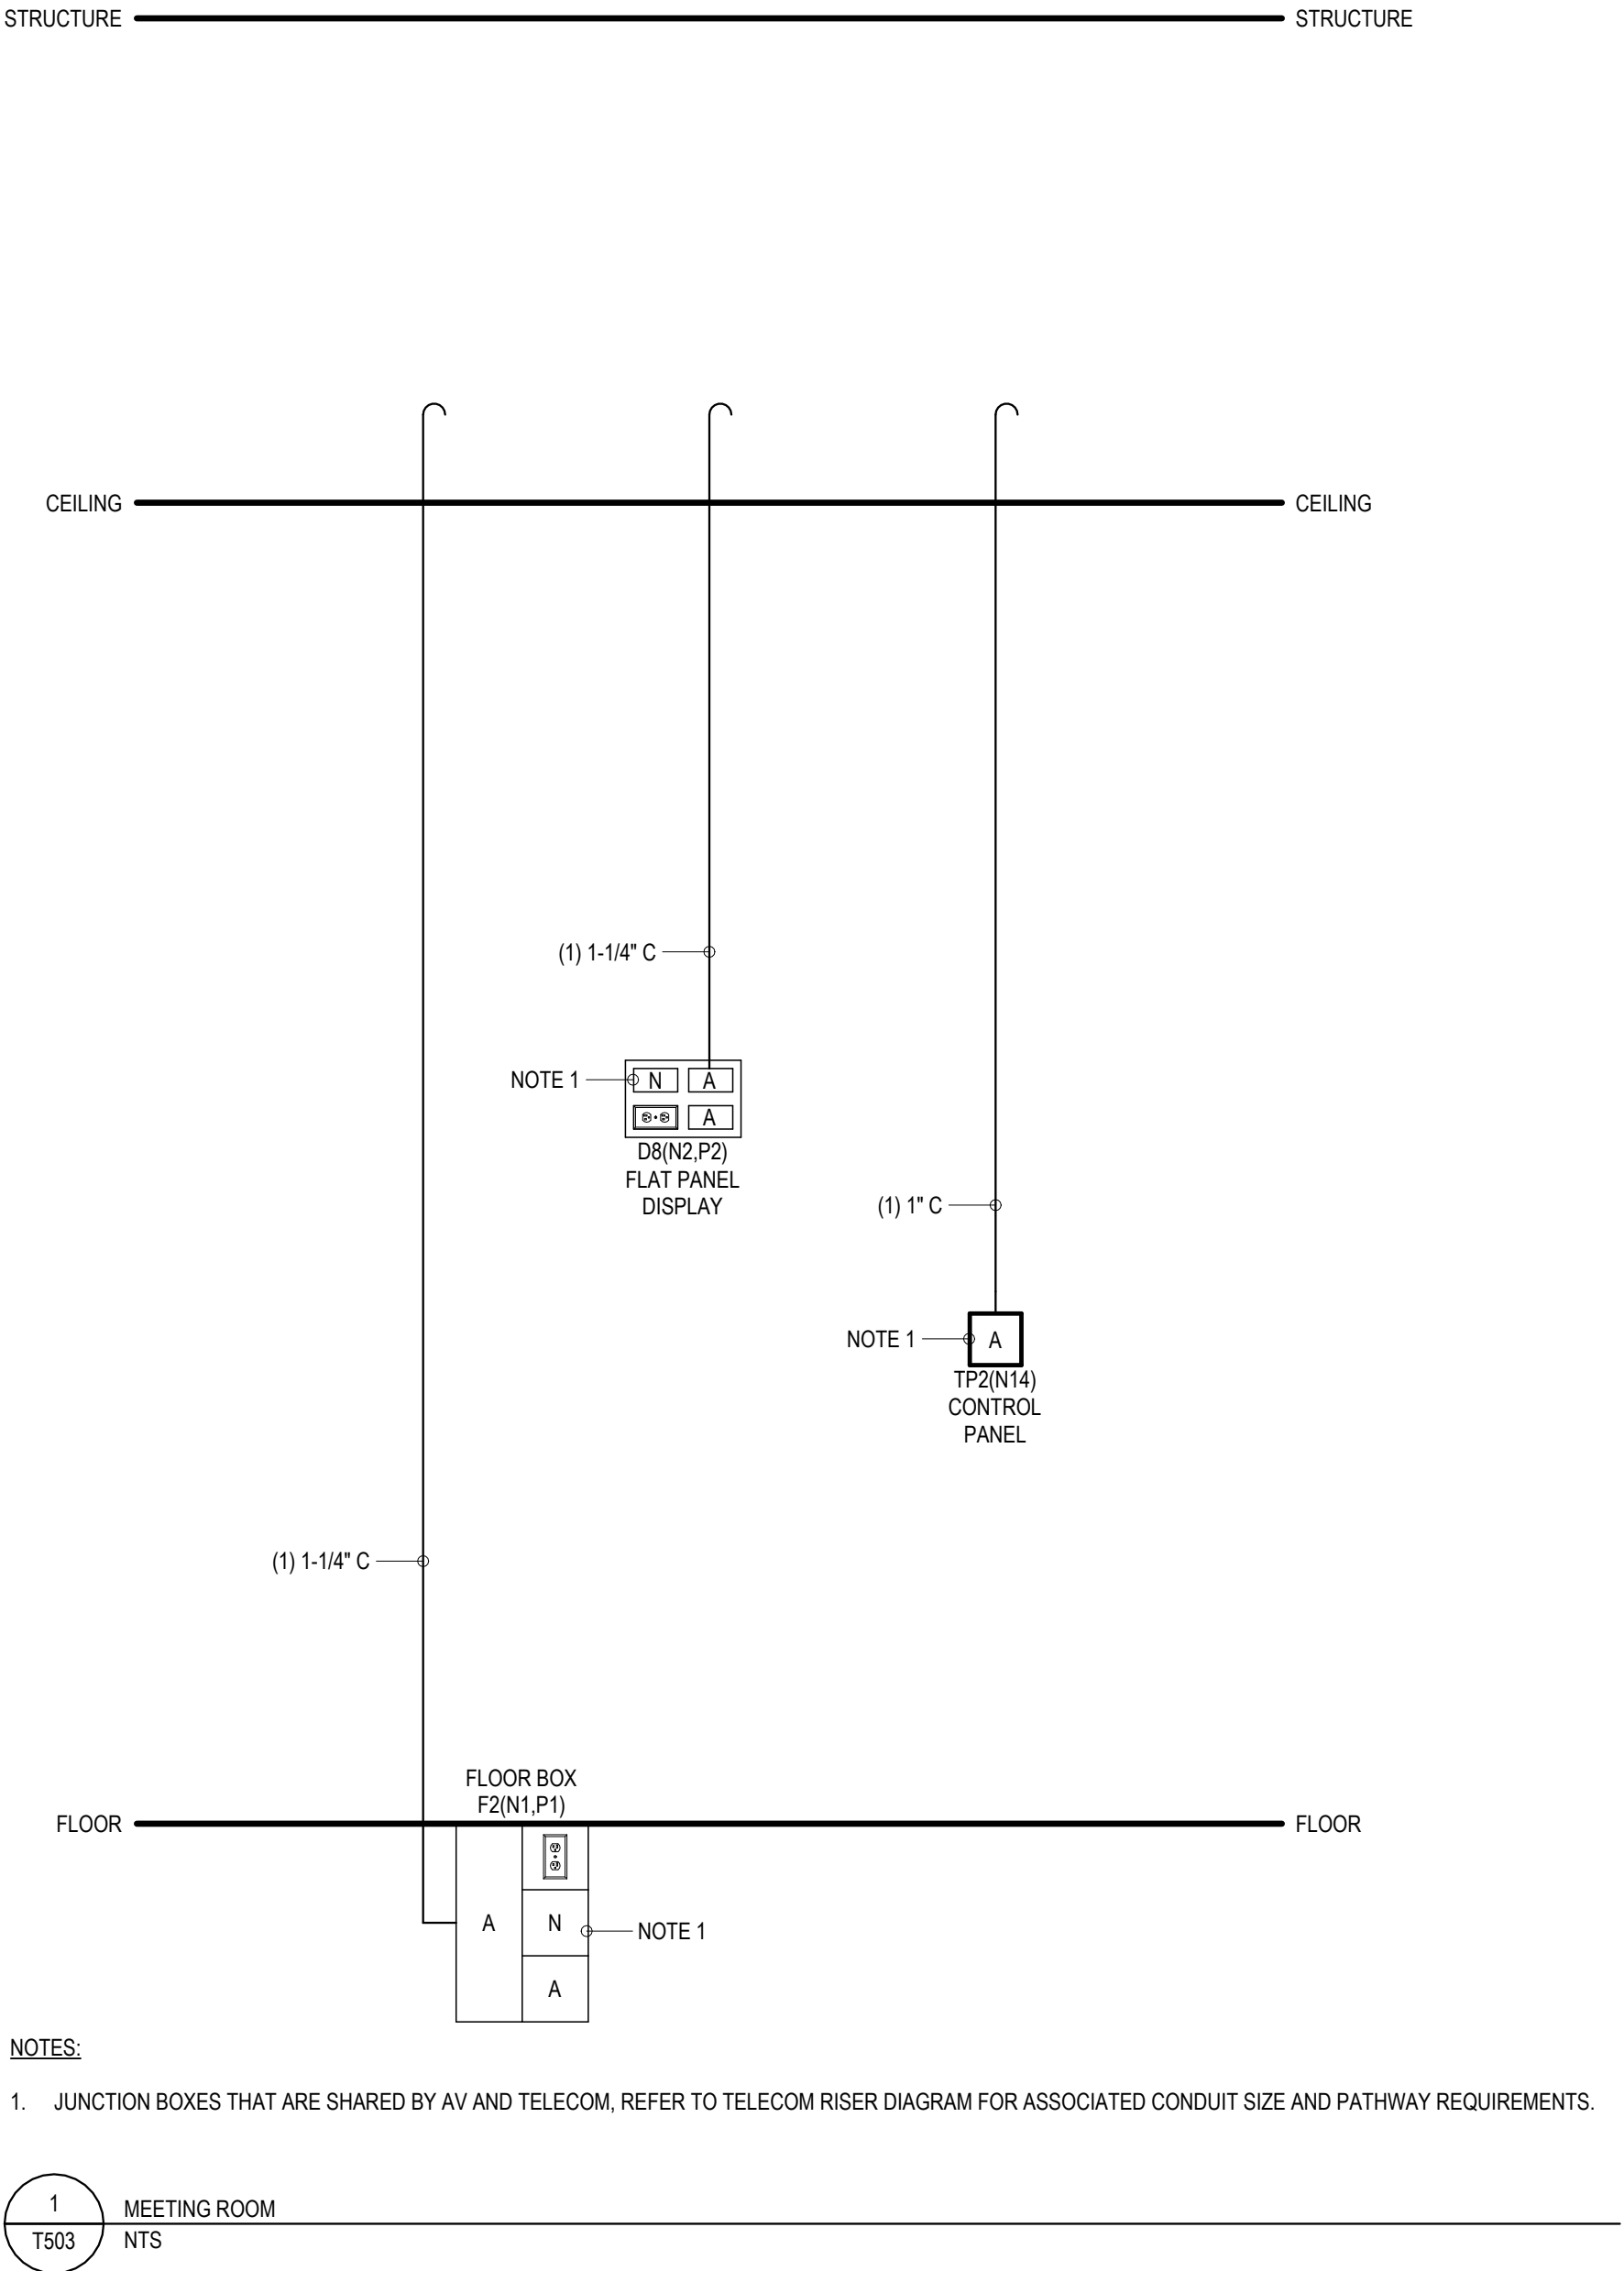

KEY PLAN

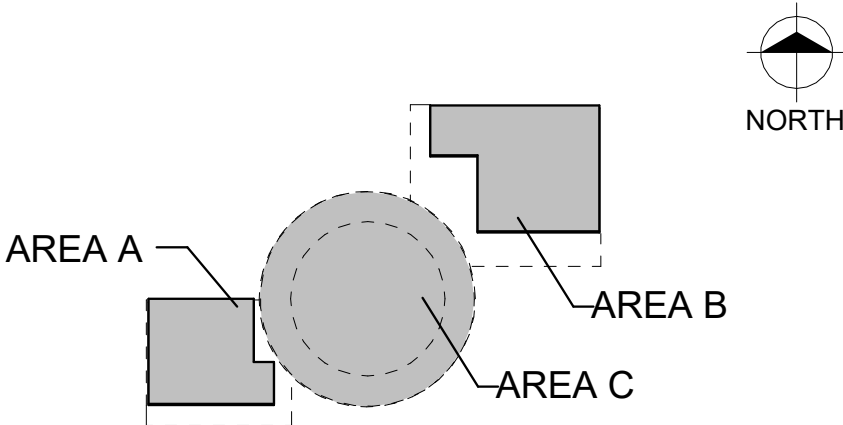

Van Buren Charter Township

Van Buren Township, MI

The Lakeside Park

REVISIONS	
10/12/2026	BID AND PERMIT SET
Drawn By	TGAUNTNER
Designer	JFISHMAN, TROBINETTE
Reviewer	DCHITTY, KKERSTETTER
Manager	CKRETOVIC




Hard copy is intended to be 24"x36" when plotted. Scale(s) indicated and graphic quality may not be accurate for any other size.

PROJECT NO.
2500281

SHEET NO.

T503

©Copyright 2026
All Rights Reserved

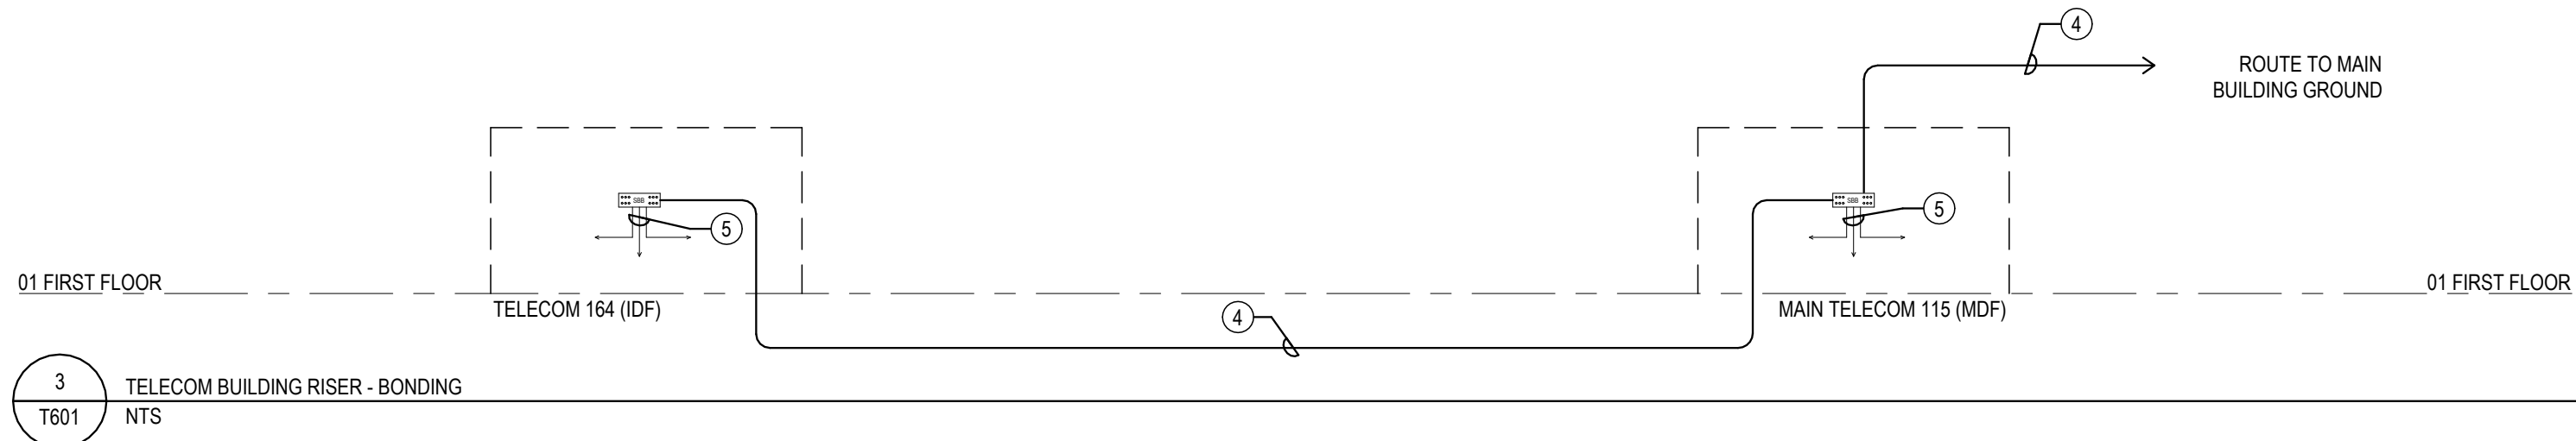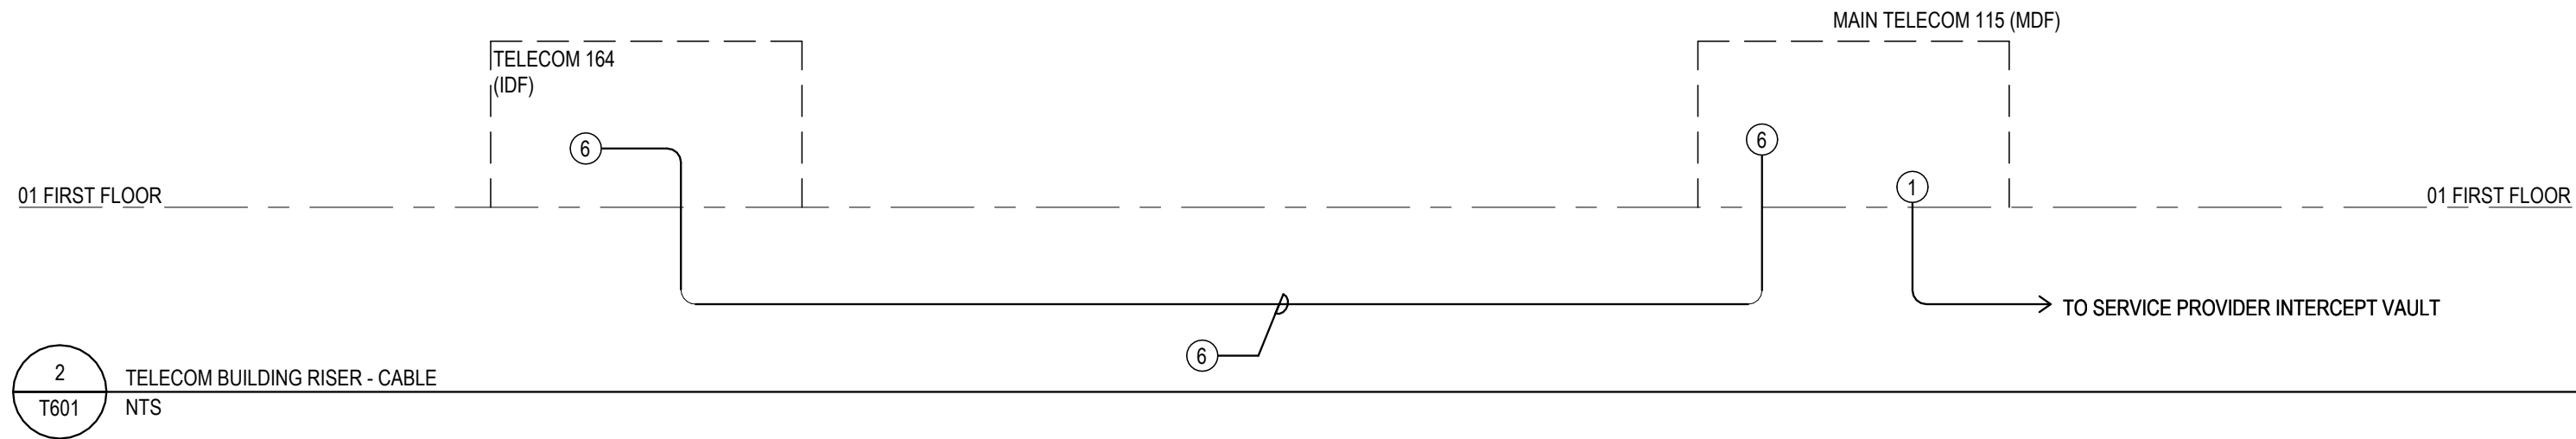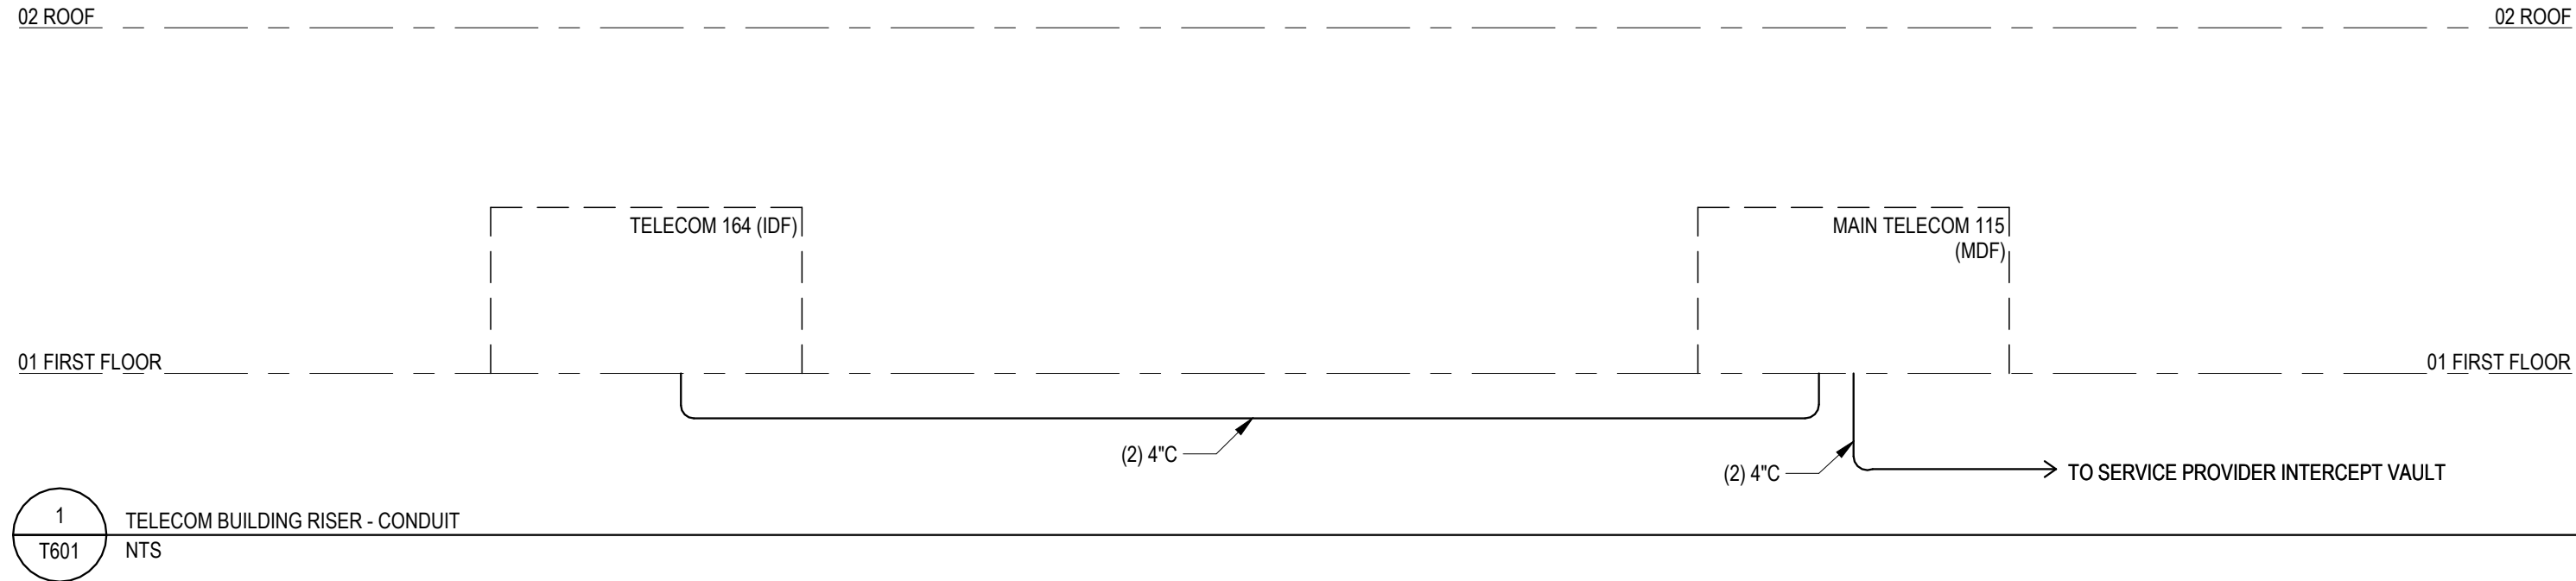

SHEET NOTES - TELECOM

- ALL CABLE BASKET AND CONDUIT FOR TELECOM SHALL BE FURNISHED AND INSTALLED BY DIVISION 26.
- REFER TO SHEET T001 FOR ALL GENERAL NOTES, LEGENDS, ABBREVIATIONS, AND SHEET INDEX.
- TELECOM BONDING BACKBONE (TBB) CONDUCTORS SHALL BE AS SIZED BY THE ELECTRICAL ENGINEER AND SHALL BE FURNISHED AND INSTALLED BY DIVISION 26.
- 6 AWG TBB CONDUCTORS SHALL BE FURNISHED AND INSTALLED BY DIVISION 27. INDIVIDUAL "HOME" RUNS SHALL BE MADE FROM THE TMGB/TGB TO EACH OPEN FRAME EQUIPMENT RACK. RACKS SHALL NOT BE DAISY CHAINED.
- CABLE RUNWAY WITHIN MDF AND TELECOM ROOM SPACES SHALL BE FURNISHED AND INSTALL BY DIVISION 27. 6 AWG GROUND CONDUCTORS SHALL BE FURNISHED AND INSTALLED BY DIVISION 27. EACH CABLE RUNWAY ASSEMBLY SHALL HAVE A MINIMUM OF ONE "HOME" RUN BACK TO THE TGB. ALL CONTIGUOUS CABLE RUNWAY SEGMENTS SHALL BE BONDED TOGETHER USING 6 AWG STRAPS AND GROUNDED ACCORDING TO SPECIFICATIONS.

BUILDING RISER CABLE SCHEDULE

# X (CABLES)		
DESIGNATION	CABLE TYPE	CABLE CONFIGURATION
1	OPTICAL	FIBER SERVICE ENTRANCE (NOT IN CONTRACT)
2	NOT USED	REFER O SHEET T002 & T003 FOR ALL TECHNOLOGY INFRASTRUCTURE SCHEDULES AND LEGENDS
3	NOT USED	UNPROTECTED COPPER, SRVICE ENTRANCE (NOT IN CONTRACT)
4	COPPER	TELECOM BONDING BACKBONE (TBB) INCLUDING ASSOCIATED PATHWAYS BY DIVISION 26
5	COPPER	6 AWG STRANDED GROUND CONDUCTOR BY DIVISION 27 (WITHIN MDF AND TELE/DATA SPACES)
6	OPTICAL	(12) FOSM + (24) FOMM, MDF TO IDF

TBB/BCC CONDUCTOR SIZE VS LENGTH

TBB/BCC LINEAR LENGHT M (FT)	CONDUCTOR SIZE (AWG)
LESS THAN 4 (13)	6
4-6 (14-20)	4
6-8 (21-26)	3
8-10 (27-33)	2
10-13 (34-41)	1
13-16 (42-52)	1/0
16-20 (53-66)	2/0
20-26 (67-84)	3/0
26-32 (85-105)	4/0
32-38 (106-125)	250 KCMIL
38-46 (126-150)	300 KCMIL
46-53 (151-175)	350 KCMIL
53-76 (176-250)	500 KCMIL
76-91 (251-300)	600 KCMIL
GREATER THAN 91 (301)	750 KCMIL

REVISIONS

10/12/2026 BID AND PERMIT SET

Drawn By TGAUNTNER
Designer JFISHMAN, TROBINETTE
Reviewer DCHITTY, KKERSTETTER
Manager CKRETOVIC

Hard copy is intended to be 24"x36" when plotted. Scale(s) indicated and graphic quality may not be accurate for any other size.


PROJECT NO.

2500281


SHEET NO.

T601


PLOT INFO: 10/2/2026 10:52:20 AM Autodesk Docs://2500281 - Van Buren Twp Lake House2026_T_2500281.rvt

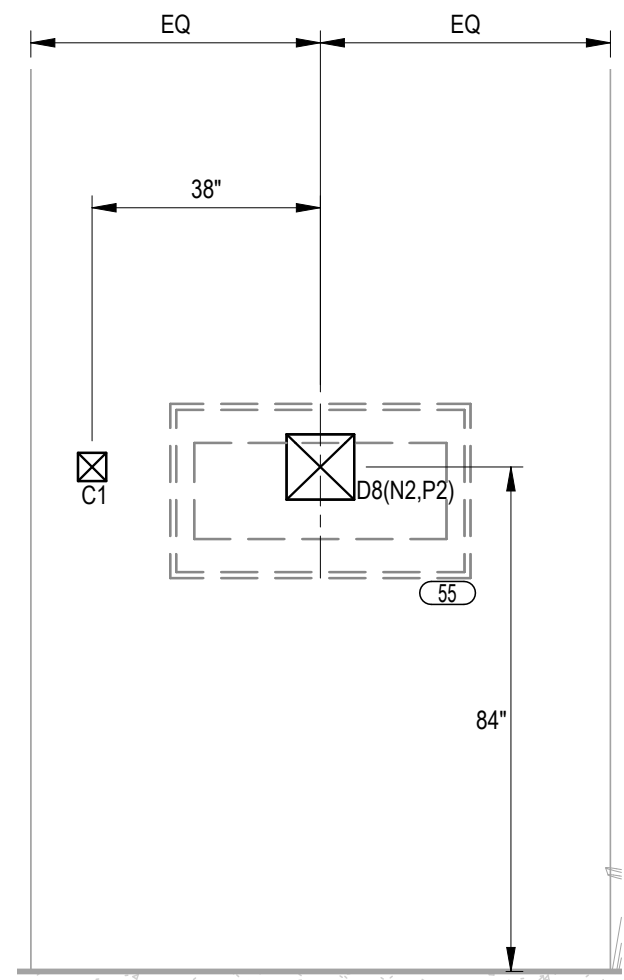


1
T701
104 - COMMUNITY LIVING ROOM
3/8" = 1'-0"

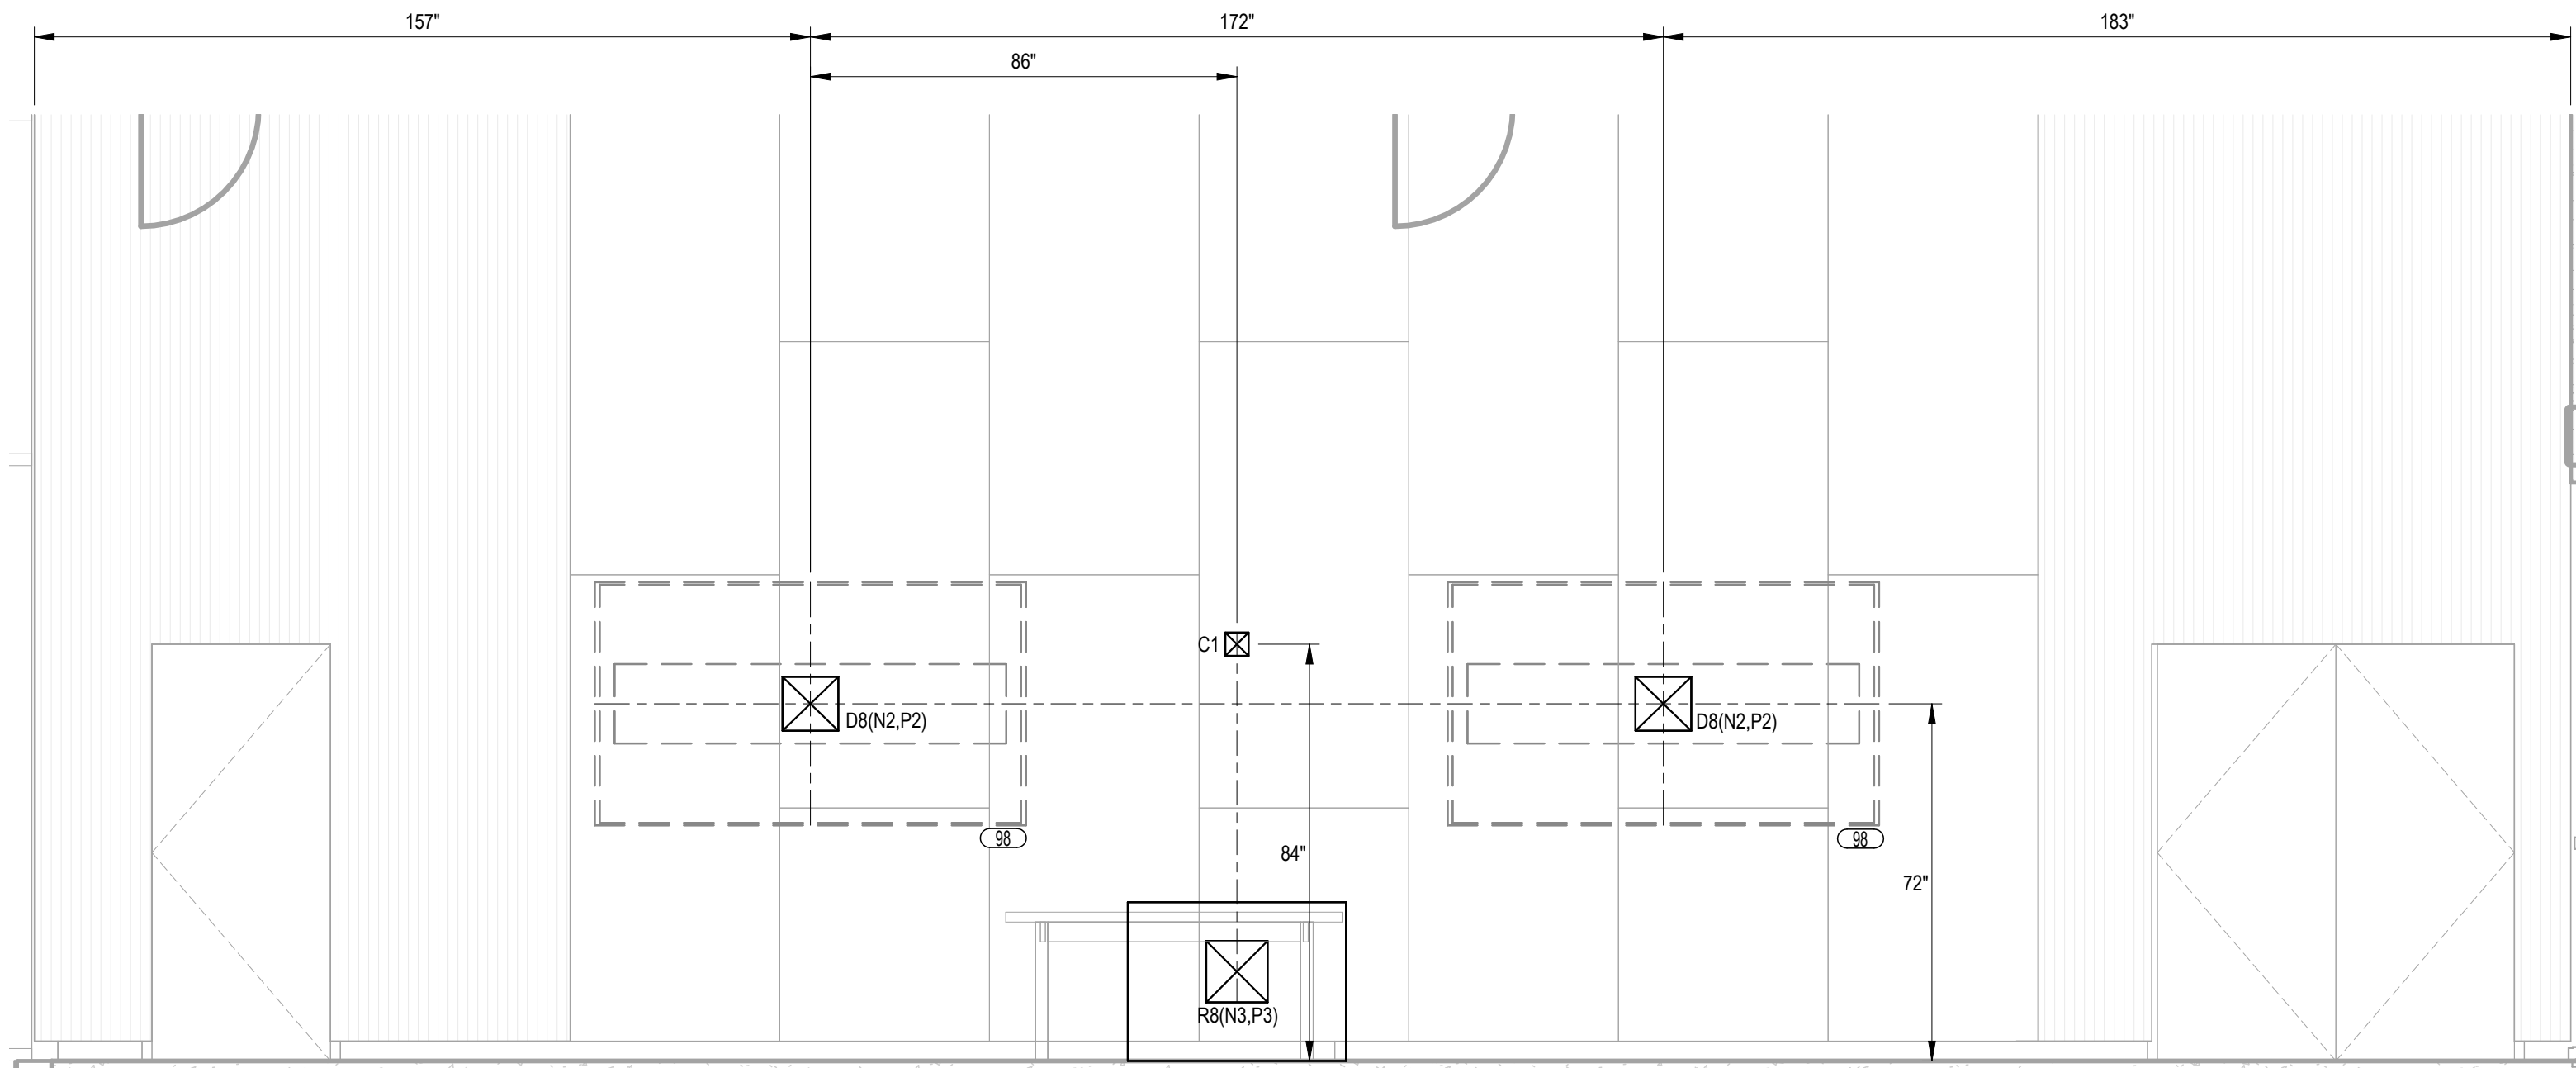


2
T701
105 - MULTI PURPOSE ROOM
3/8" = 1'-0"

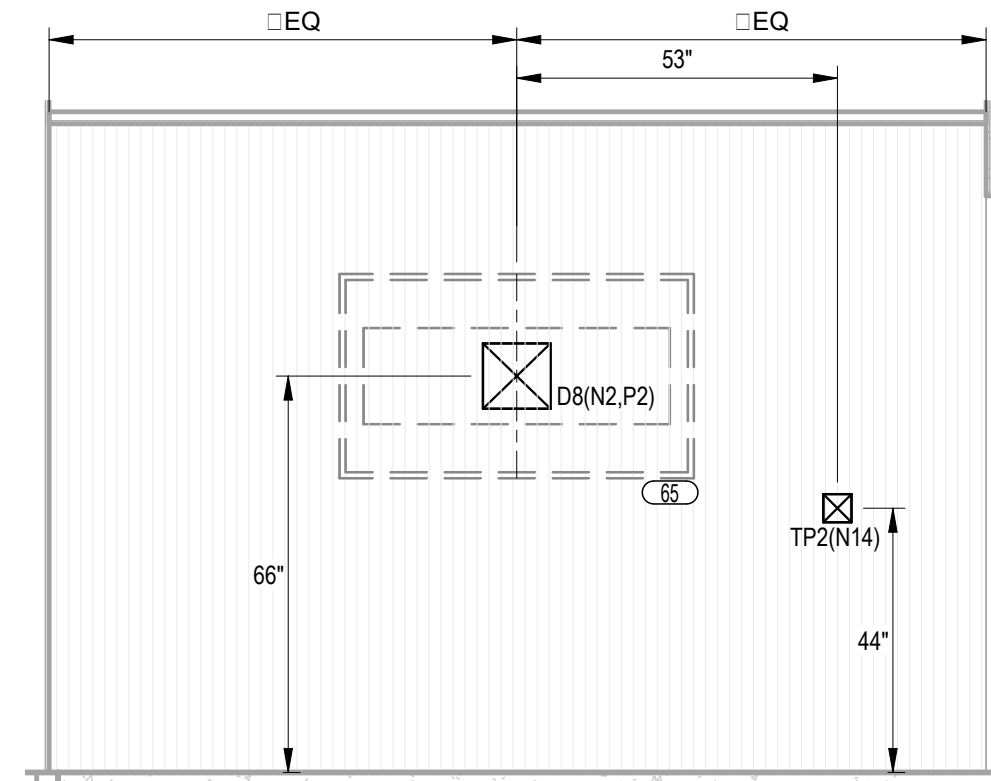

3
T701
118 - MEETING
3/8" = 1'-0"

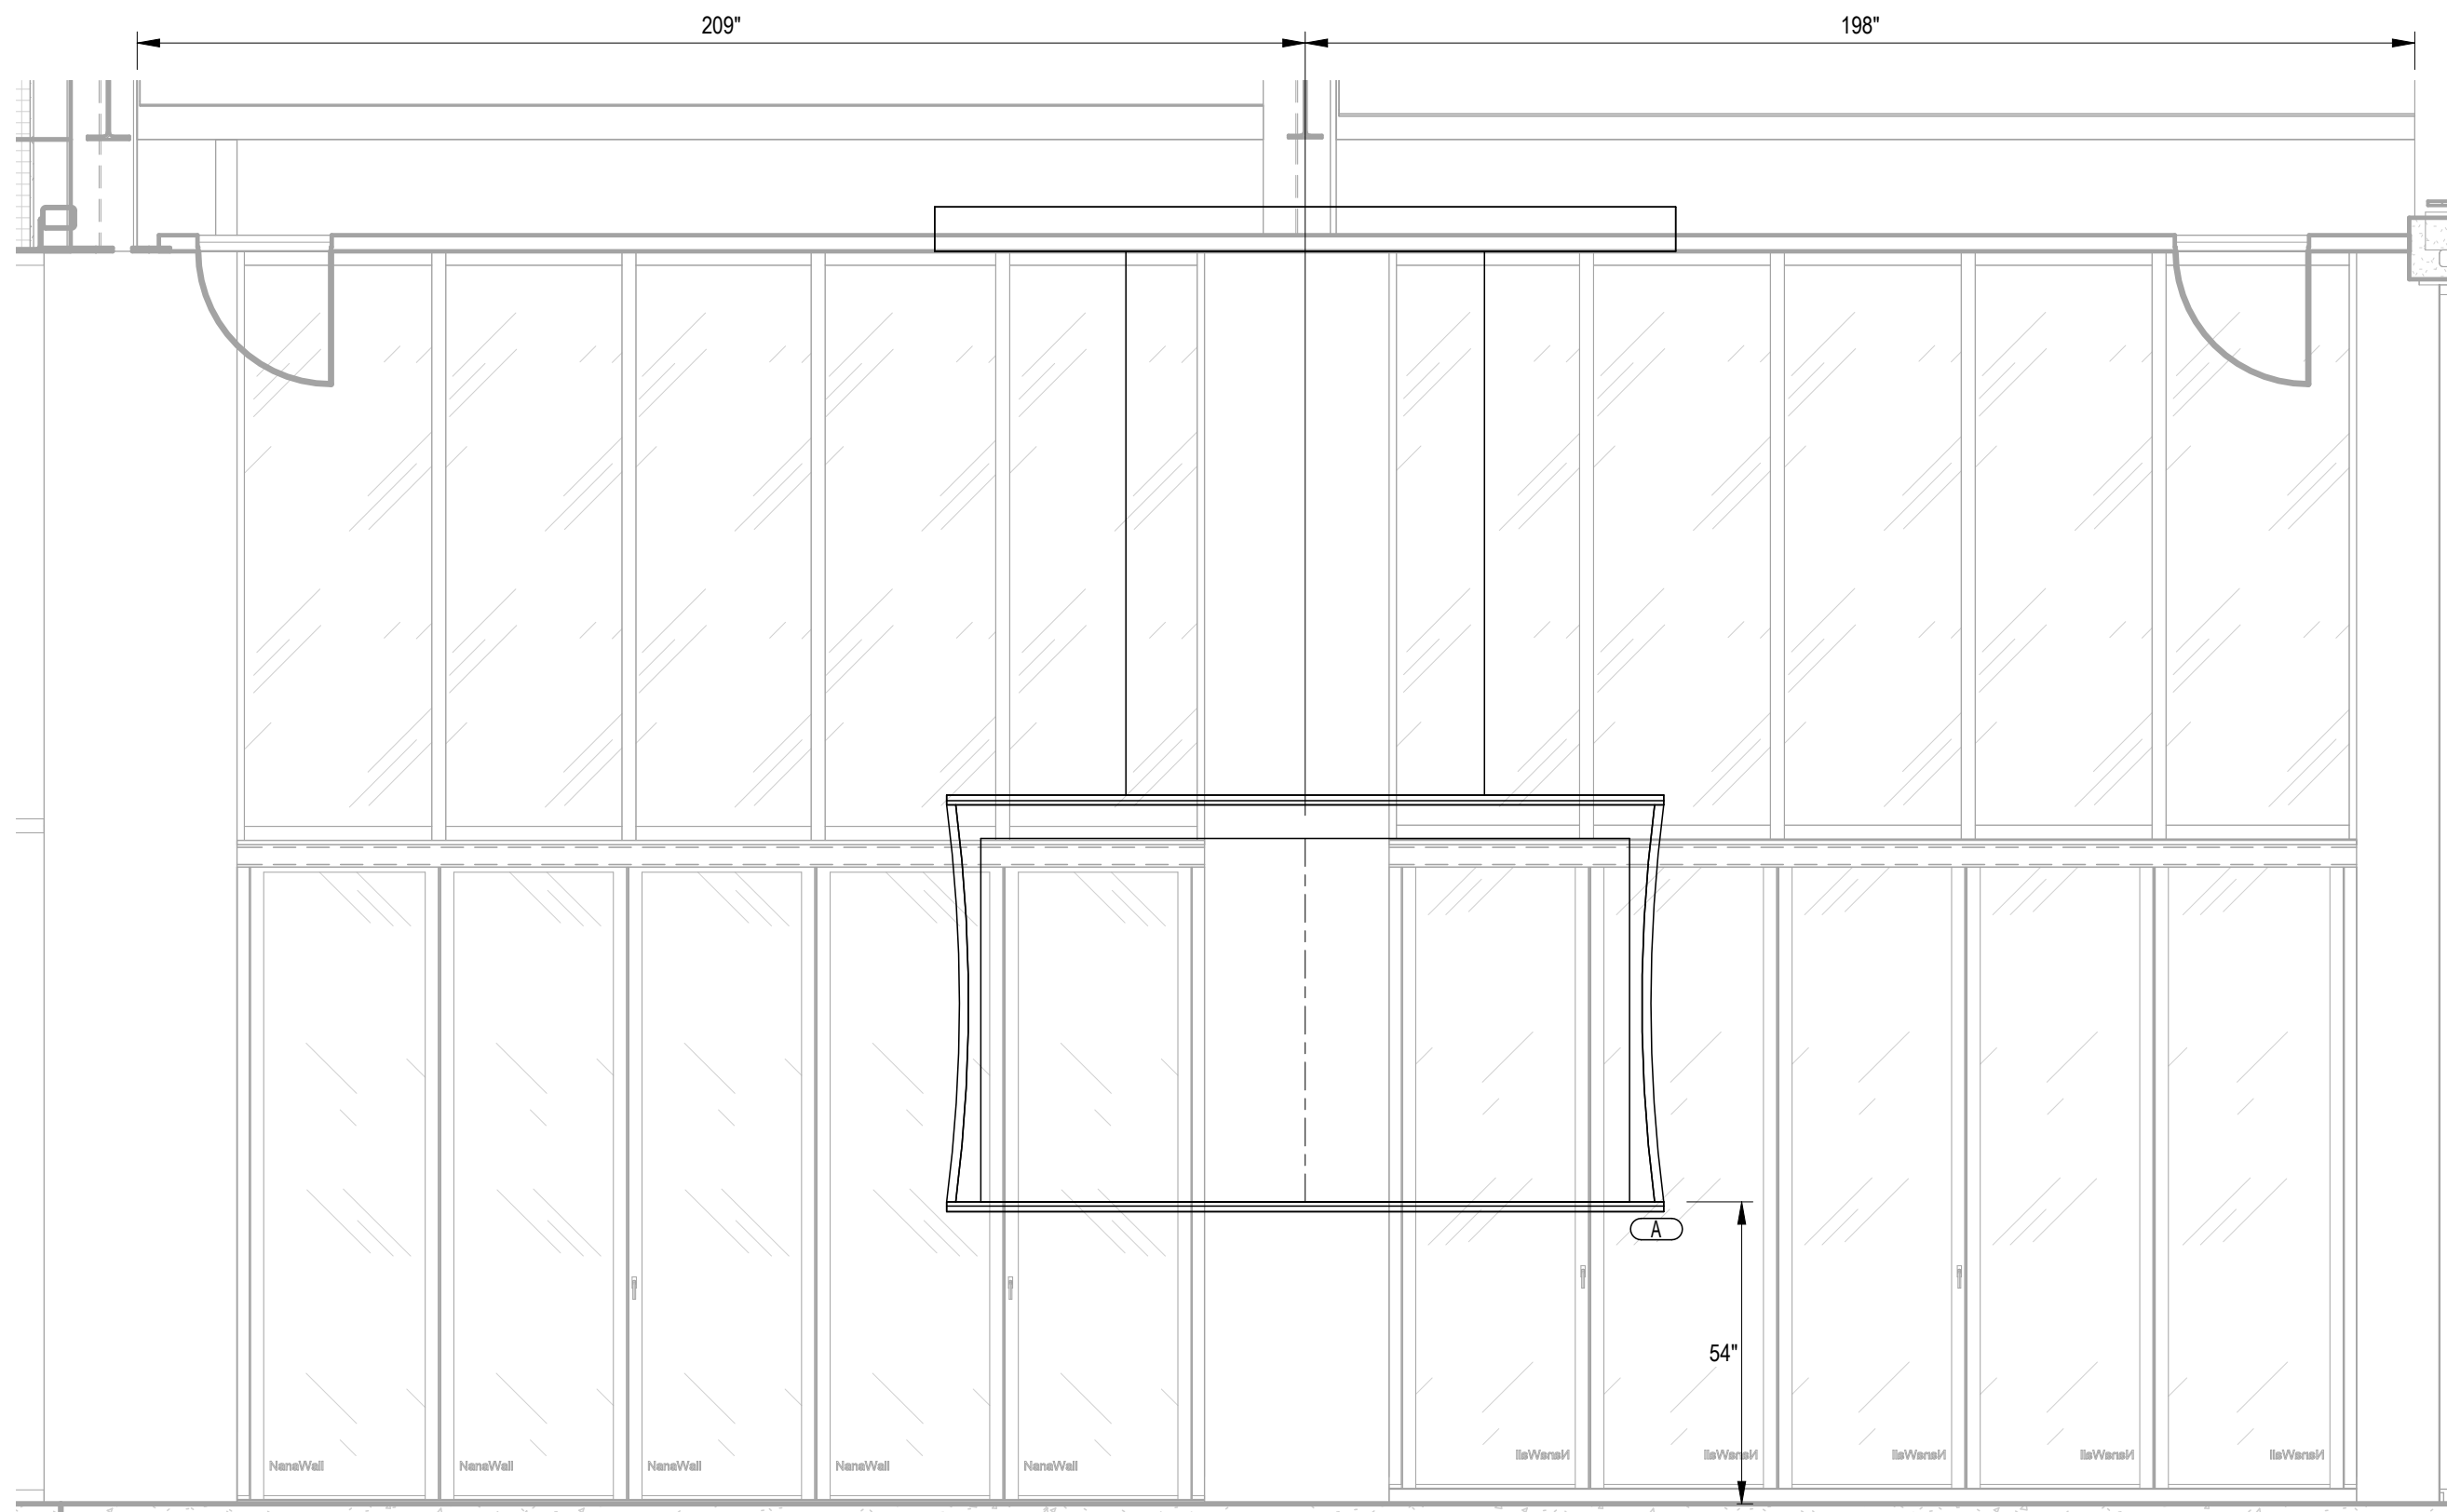

4
T701
169 - BALLROOM
3/8" = 1'-0"

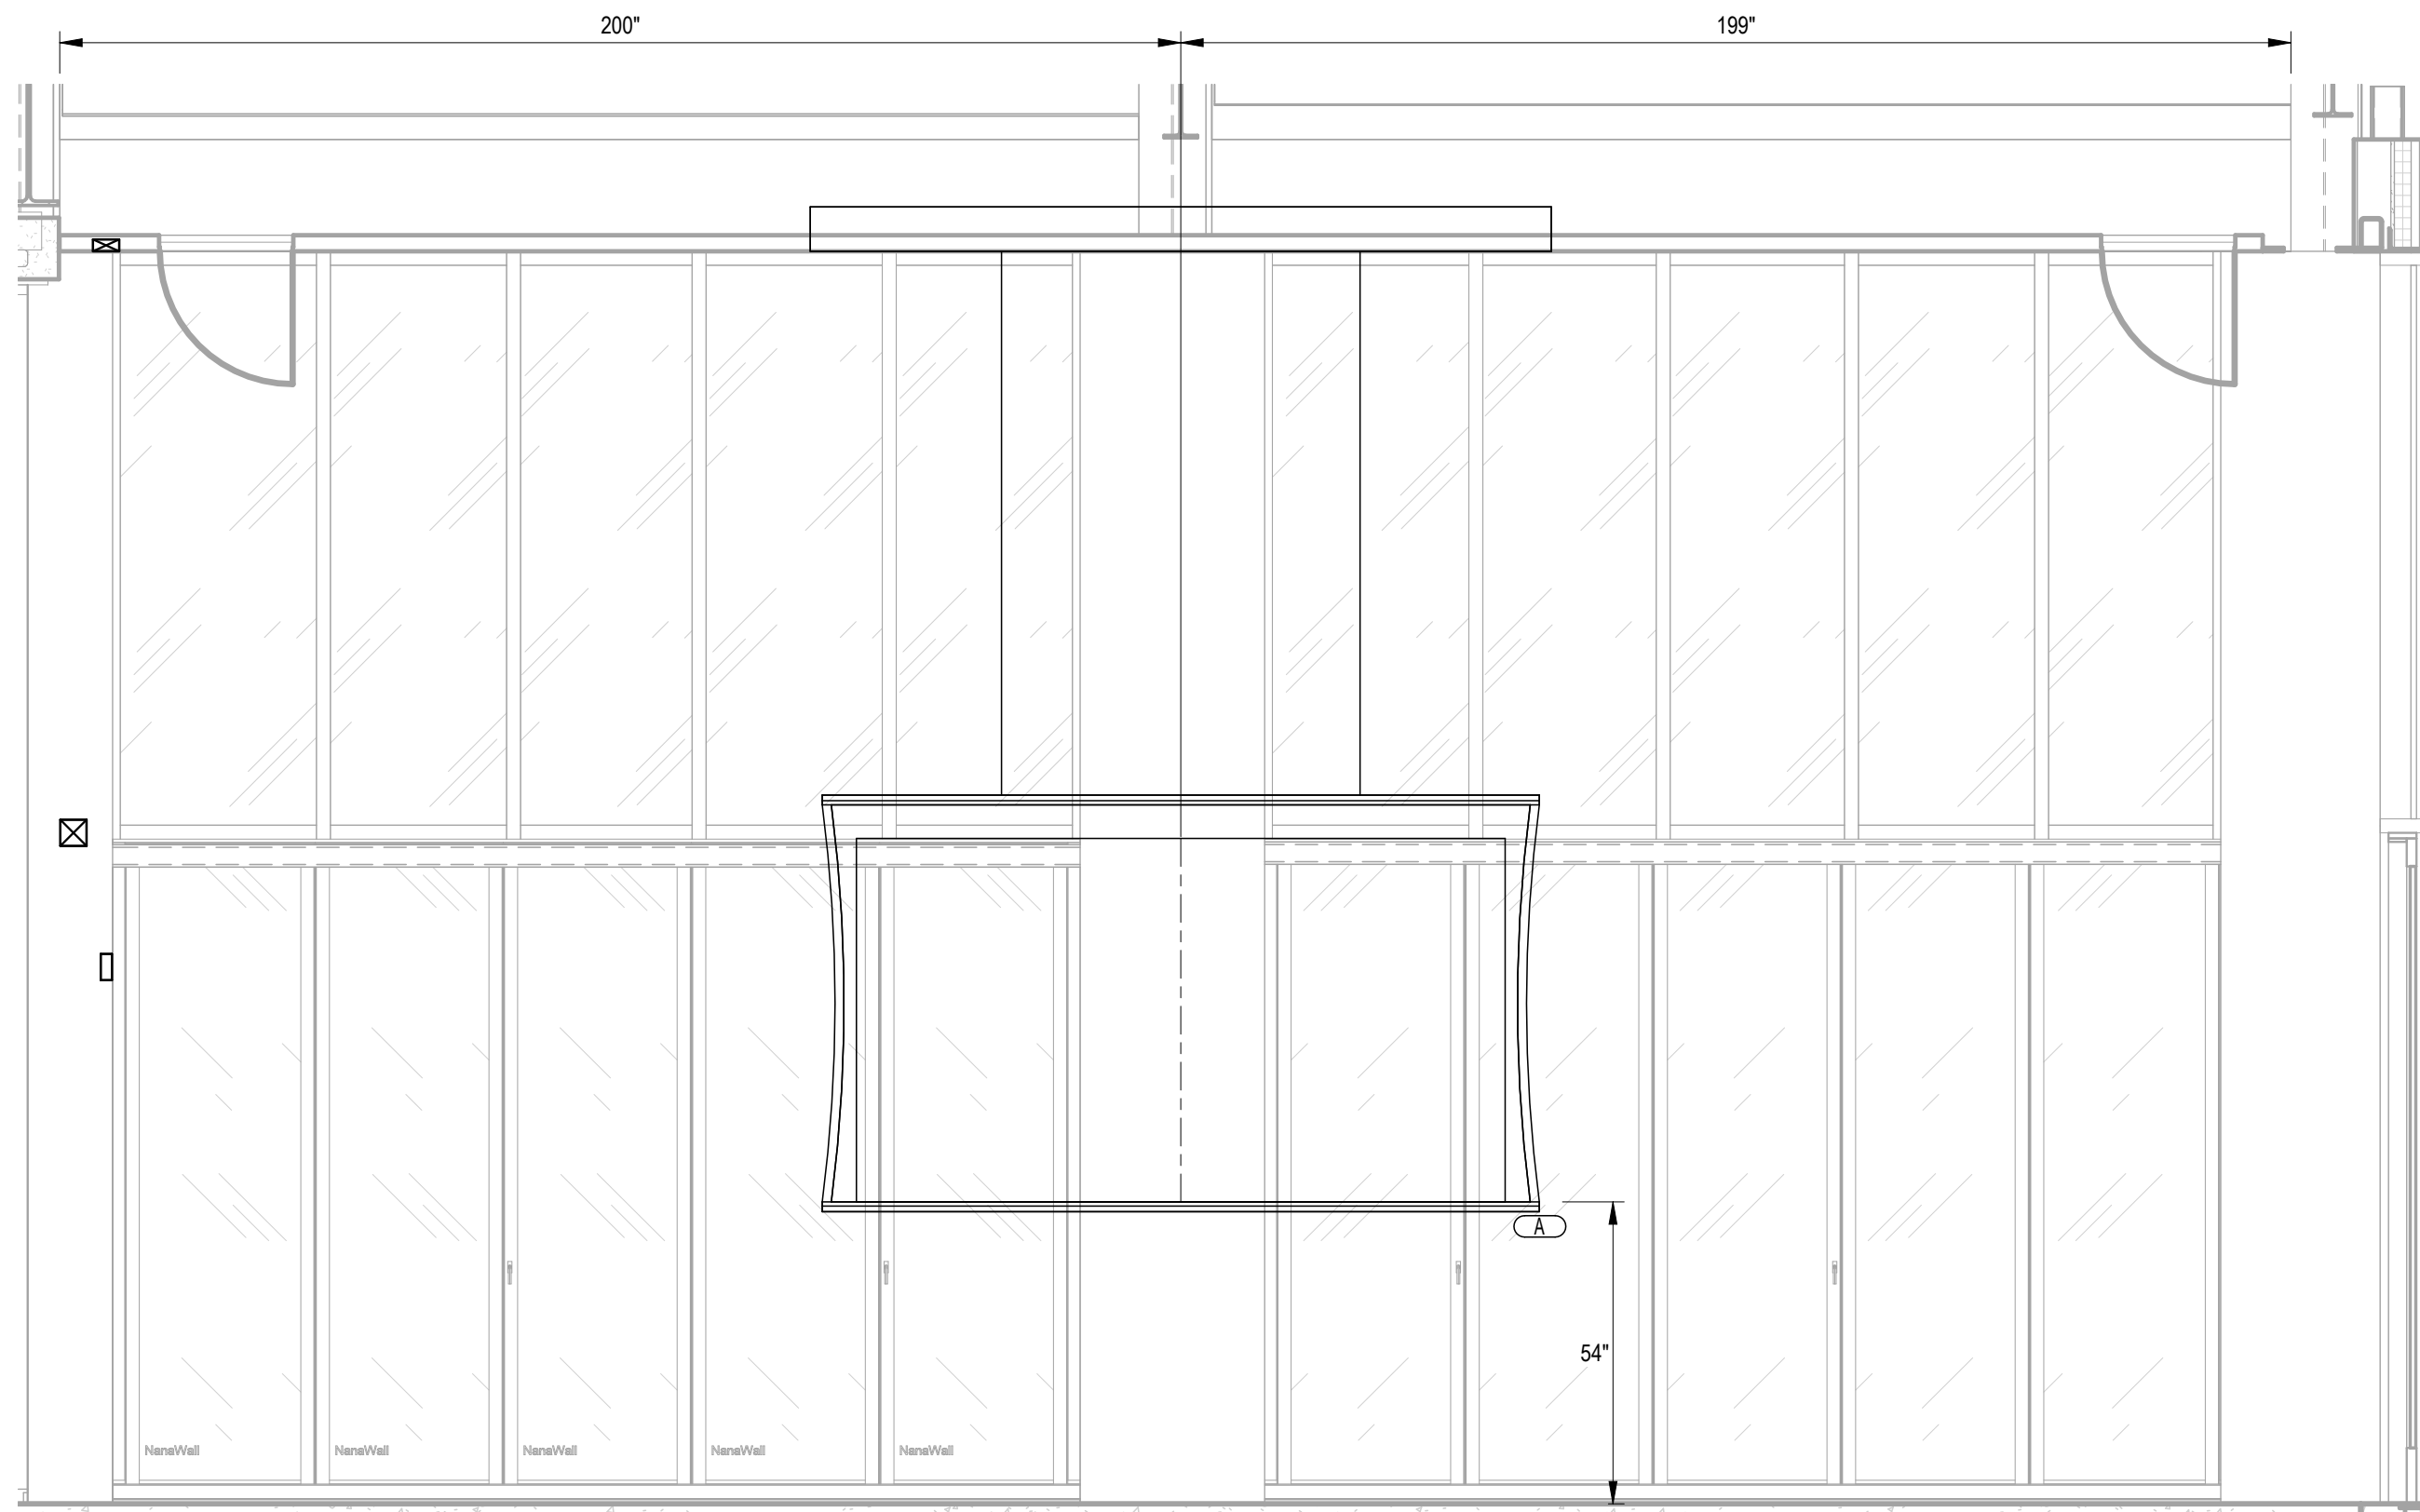

5
T701
170 - BALLROOM
3/8" = 1'-0"

REVISIONS

10/12/2026	BID AND PERMIT SET
Drawn By	TGAUNTNER
Designer	JFISHMAN, TROBINETTE
Reviewer	DCHITTY, KKERSTETTER
Manager	CKRETOVIC


Hard copy is intended to be
24"x36" when plotted. Scale(s)
indicated and graphic quality may
not be accurate for any other size.

PROJECT NO.
2500281

SHEET NO.

T701



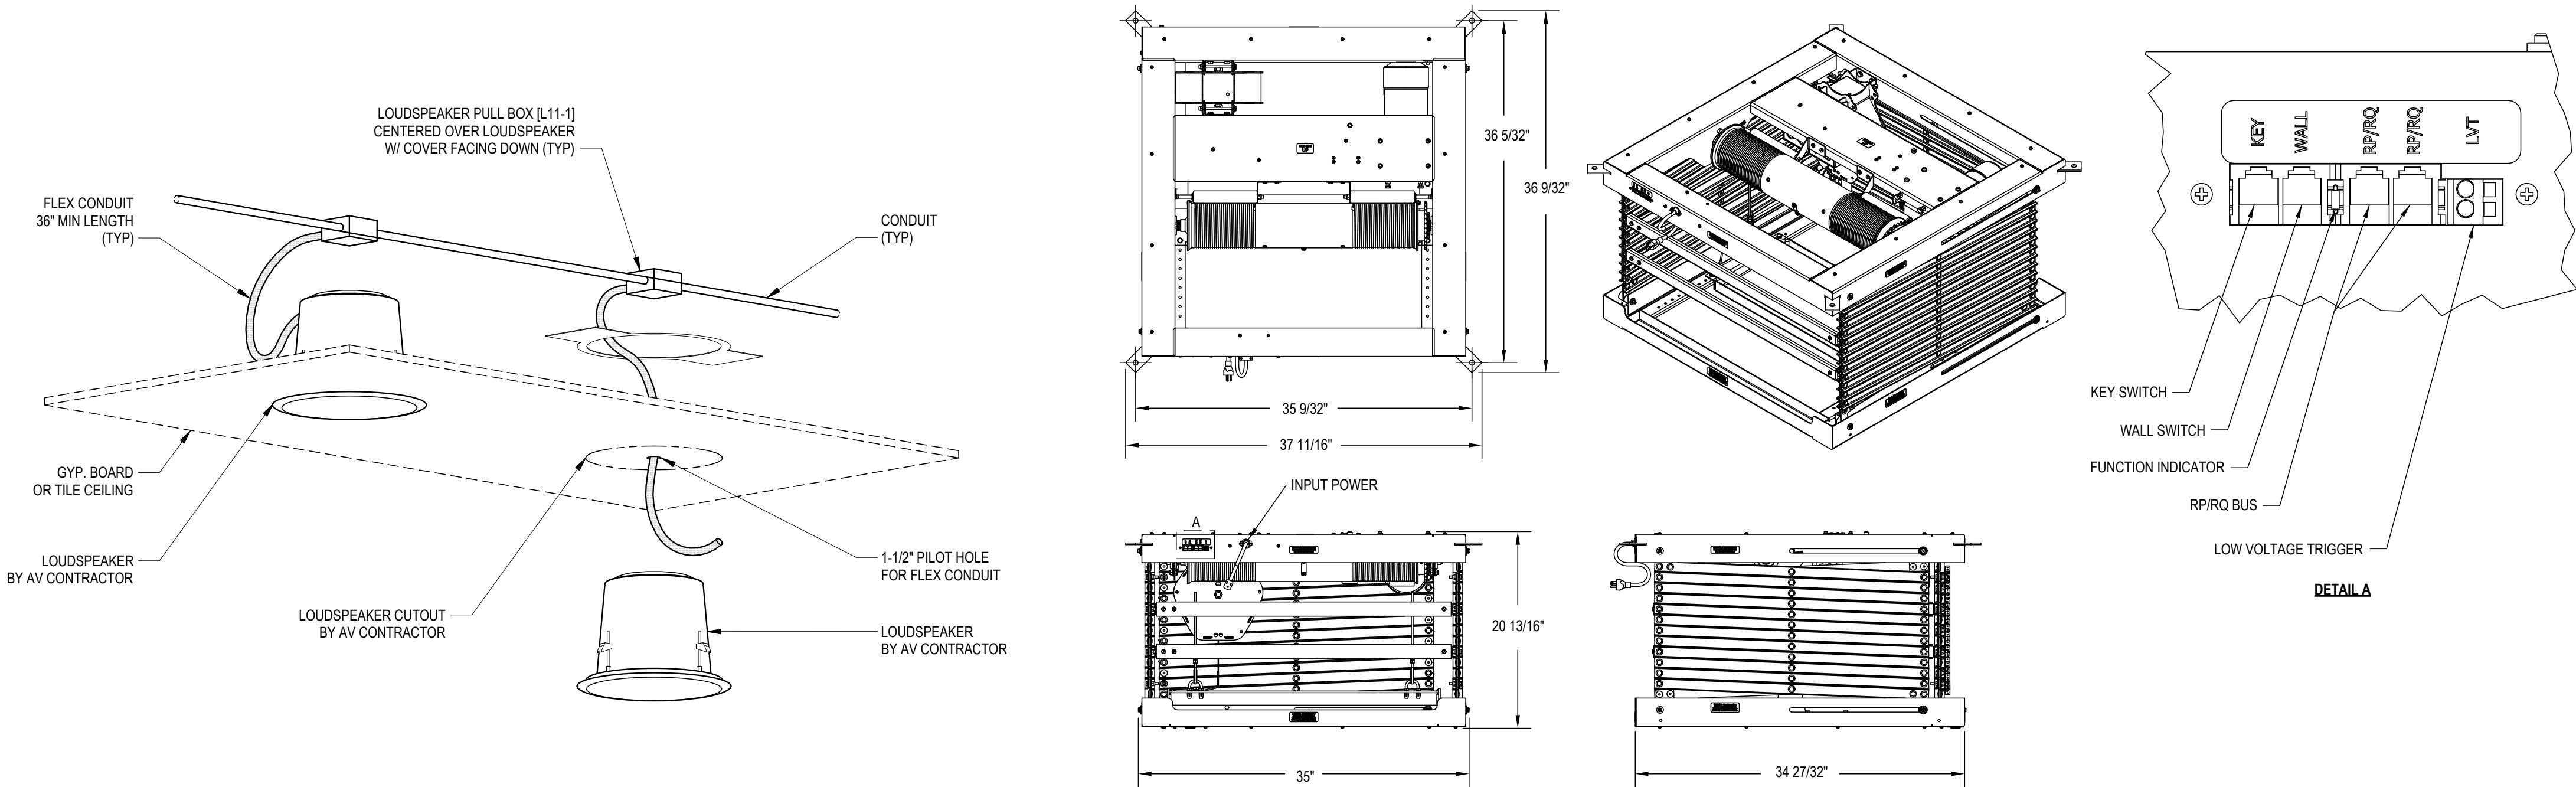

NOTES:


1. UNLESS OTHERWISE INDICATED GENERAL CONTRACTOR TO PROVIDE ALL ELEMENTS SHOWN.

2. GENERAL CONTRACTOR TO PROVIDE PULL STRINGS IN ALL CONDUITS.

1
T802

LOUDSPEAKER INSTALLATION FOR LAY-IN OR GYP. BOARD CEILING

NTS

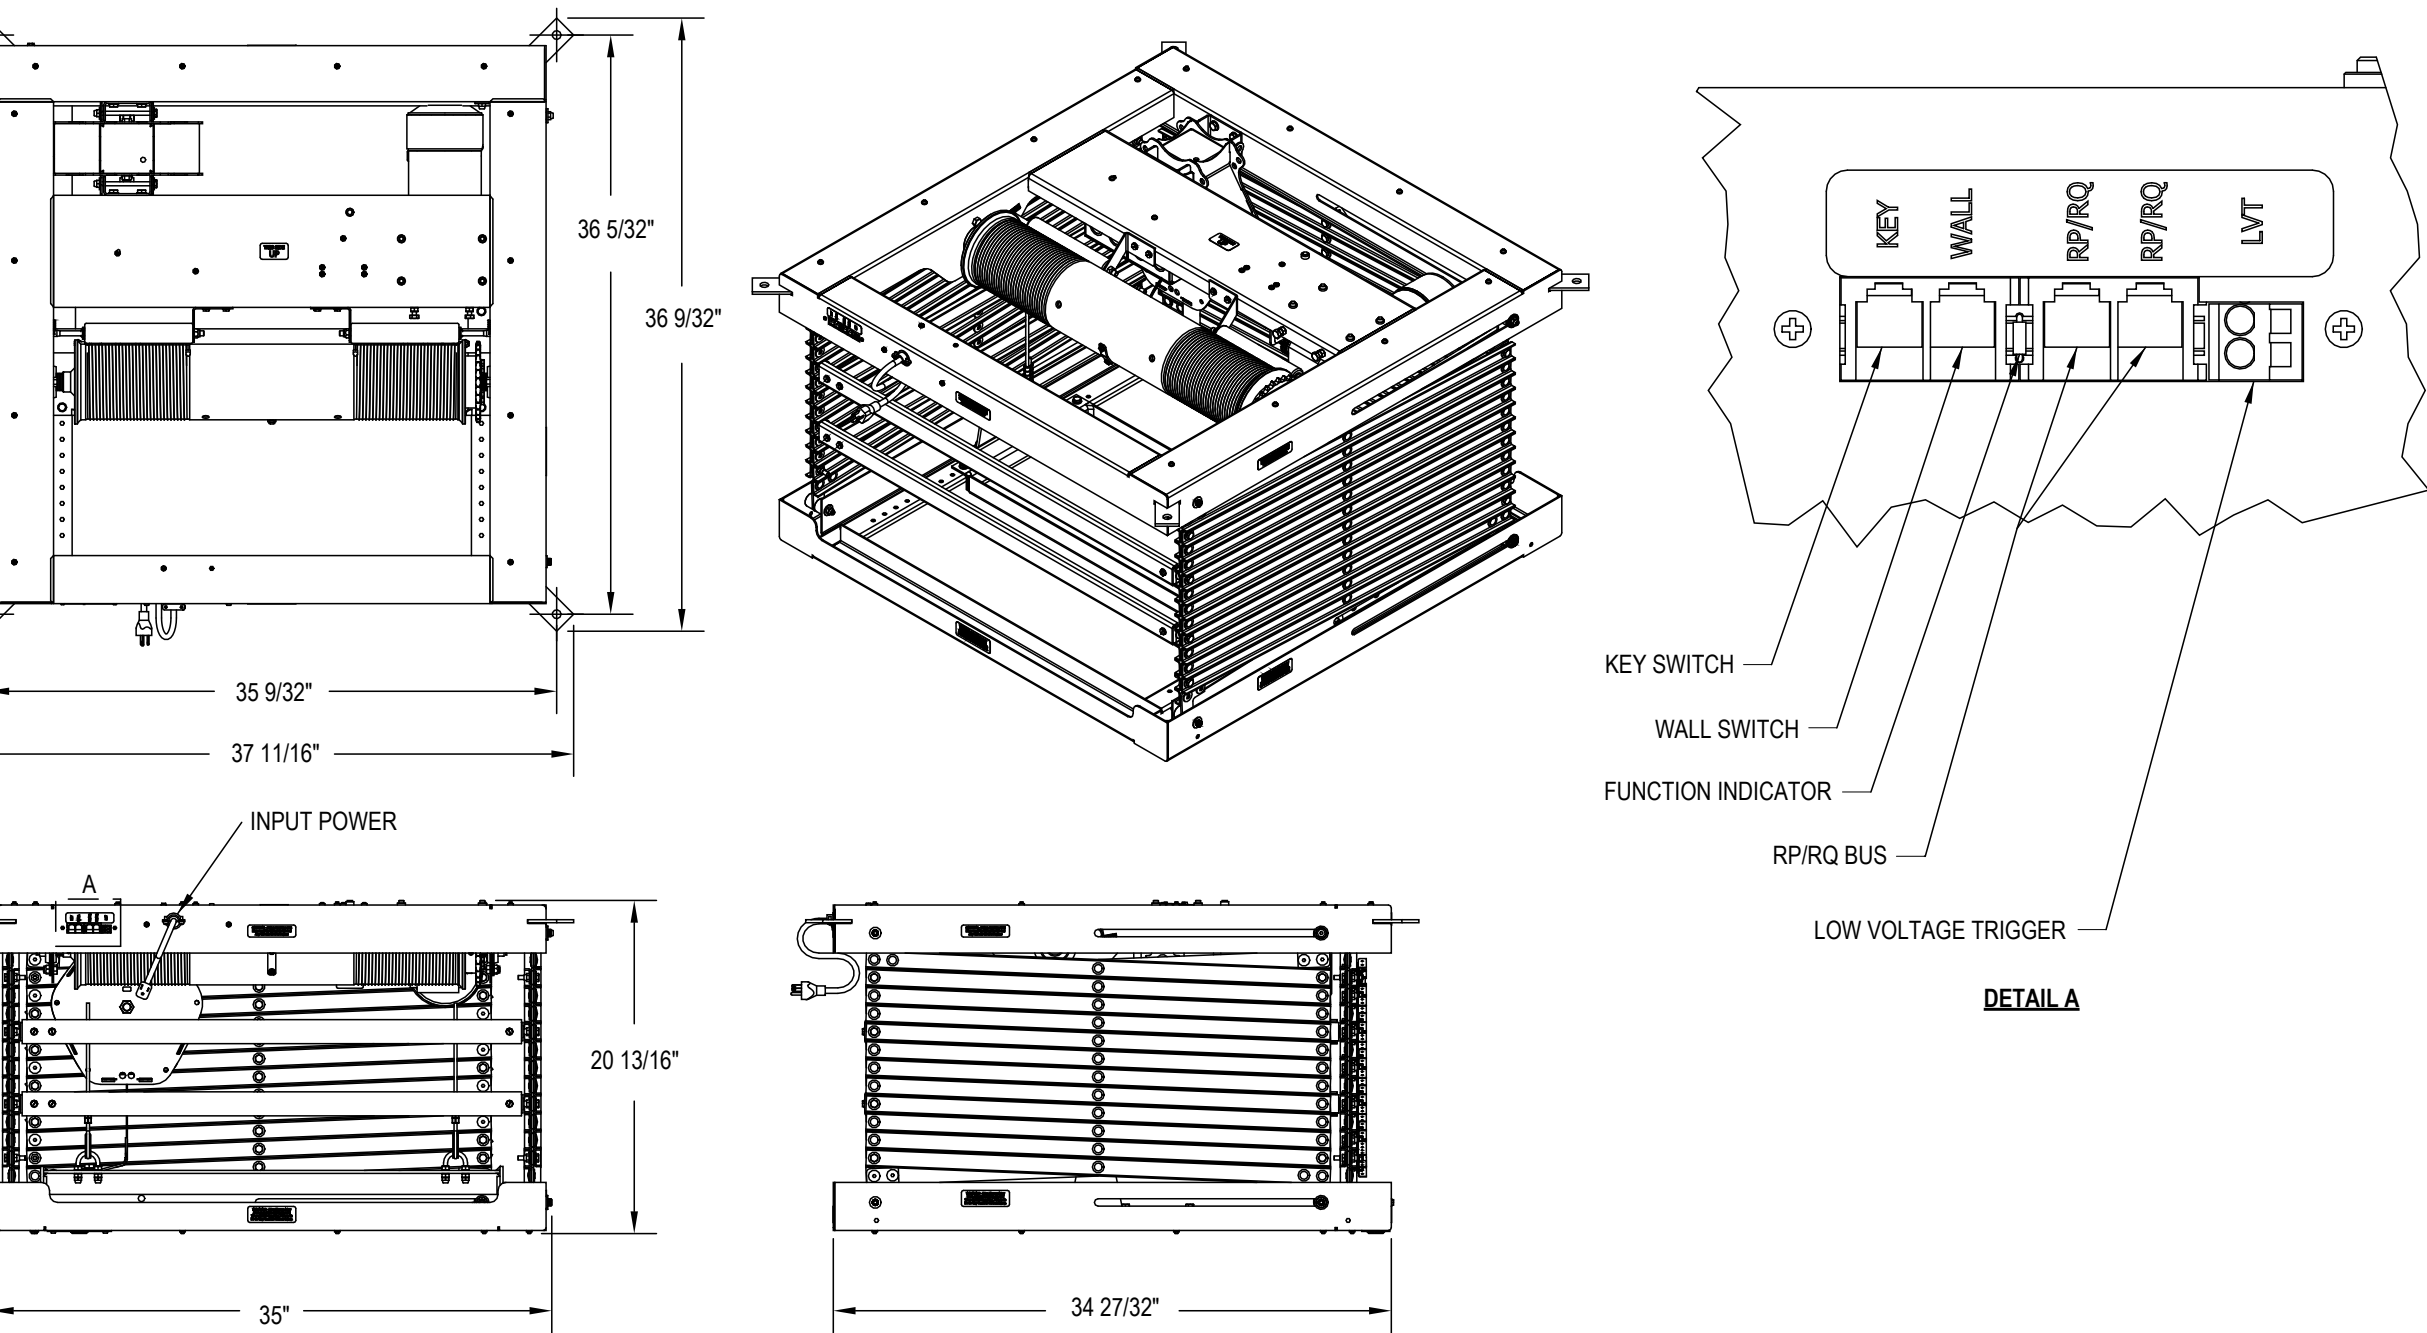

NOTES:

1. PROVIDE MODEL WITH EXTENDED HEIGHT THAT ALLOWS FOR MAINTENANCE POSITION OF 6' AFF.


2. CONTRACTOR TO HARDWIRE ELECTRICAL TO THE LIFT AND ENSURE A RECEPTACLE IS INCLUDED WITHIN. REFER TO MANUFACTURER'S INSTRUCTIONS.

3. PROVIDE FINISH PER NOTES ON T002 WITH RS-232 CONTROL MODULE, RS-232 CABLE HARNESS, AND HDMI CABLE HARNESS.

2
T802

DRAPER SLX SCISSOR PROJECTOR LIFT

NTS

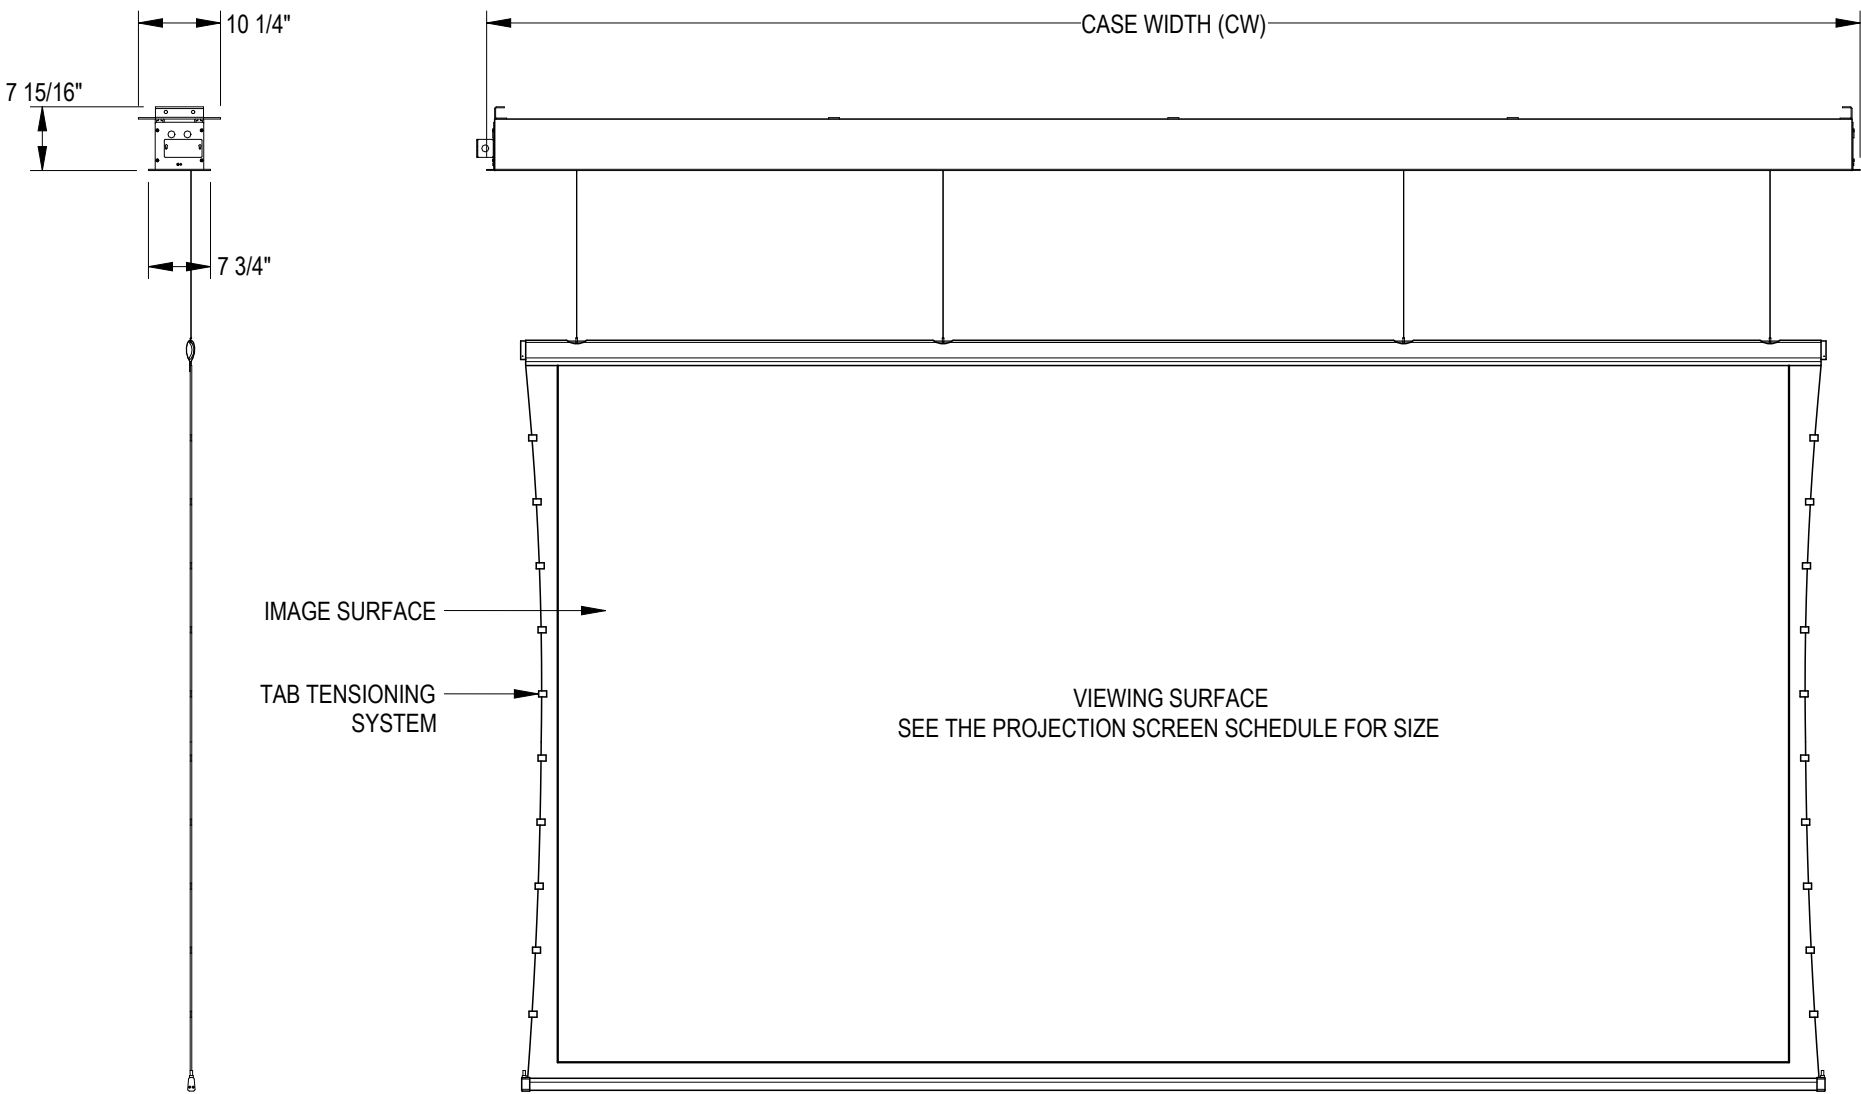


3
T802

DA-LITE TENSIONED ADVANTAGE SIGHTLINE PROJECTION SCREEN

1/2\" = 1'-0"

KEY PLAN

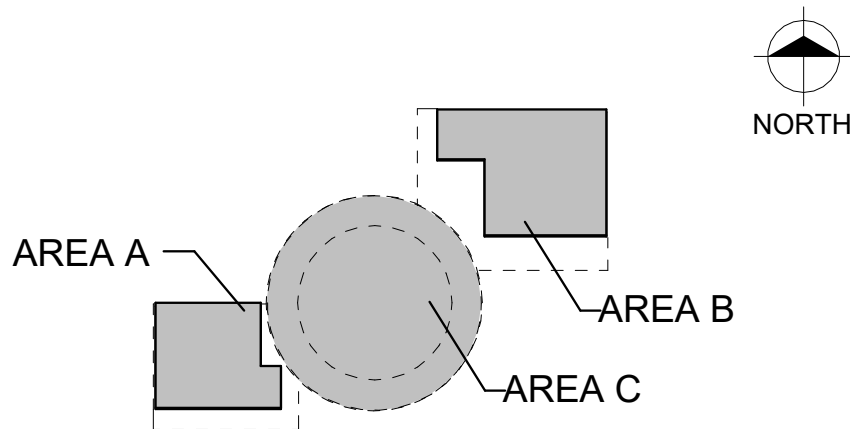

Van Buren Charter Township

Van Buren Township, MI

The Lakeside Park

REVISIONS

10/12/2026 BID AND PERMIT SET

Drawn By	TGAUNTNER
Designer	JFISHMAN, TROBINETTE
Reviewer	DGHITY, KKERSTETTER
Manager	CKRETOVIC


Hard copy is intended to be 24"x36" when plotted. Scale(s) indicated and graphic quality may not be accurate for any other size.

PROJECT NO.
2500281

SHEET NO.




T802

PLOT INFO: 10/2/2026 10:52:22 AM Autodesk Docs://2500281 - Van Buren Twp Lake House2026_T_2500281.rvt

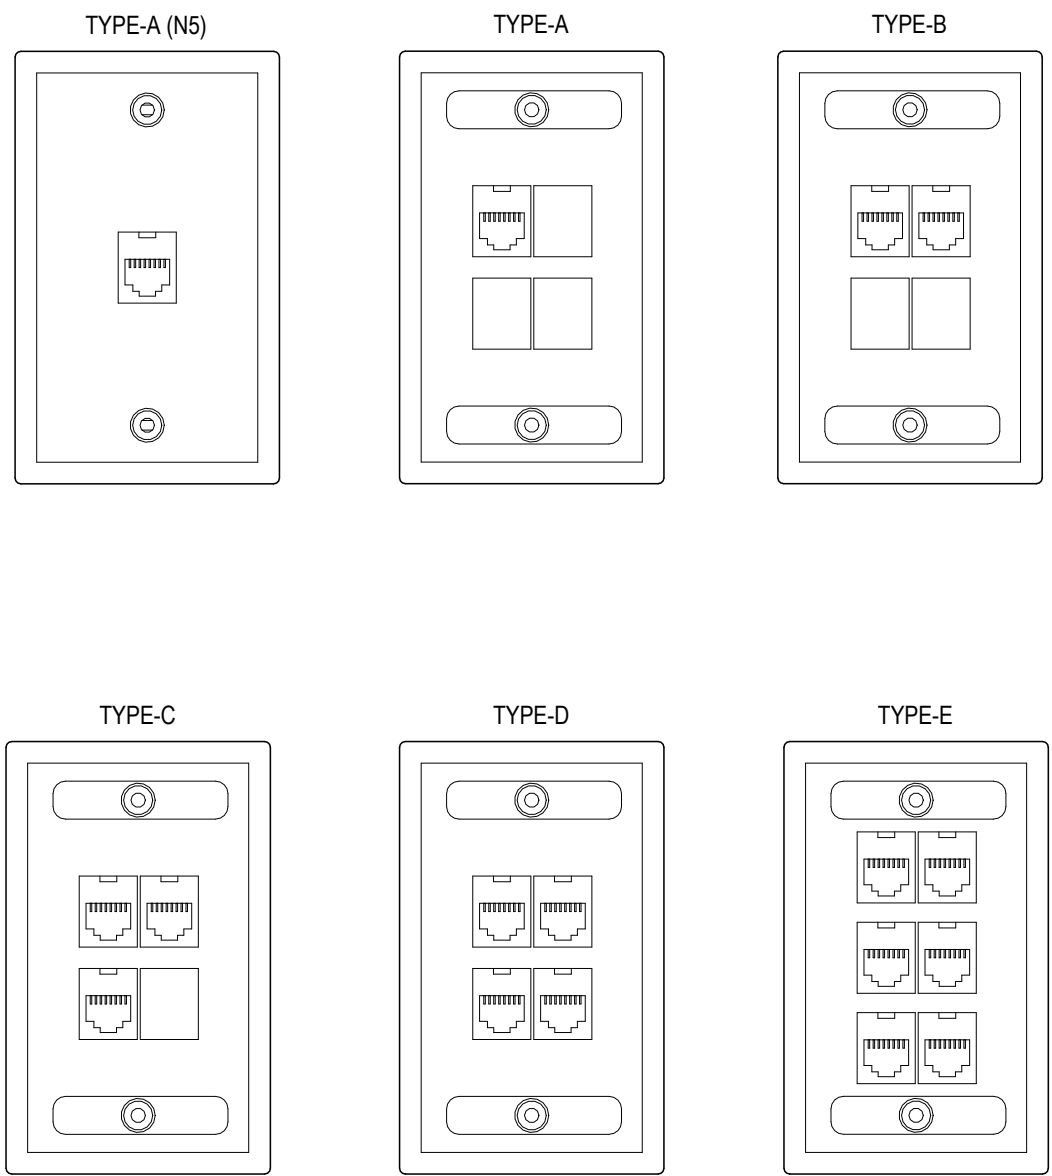


NOTES:

 1. CONTRACTOR MUST PROVIDE THE NECESSARY SPECIALTY TERMINATION PLATES AND / OR ADAPTERS FOR FLOOR BOXES, POKE-THRU'S, SPECIALTY BOXES. REFER TO TECHNOLOGY LEGEND NOTES, DETAILS, AND MANUFACTURER FOR MORE INFORMATION.

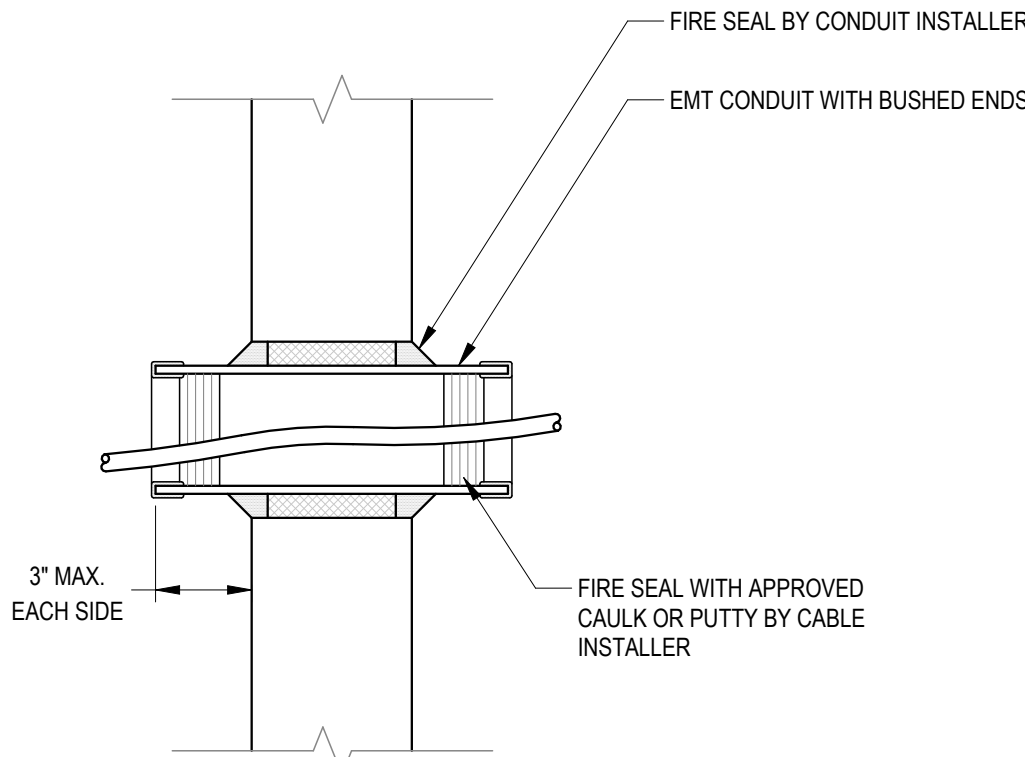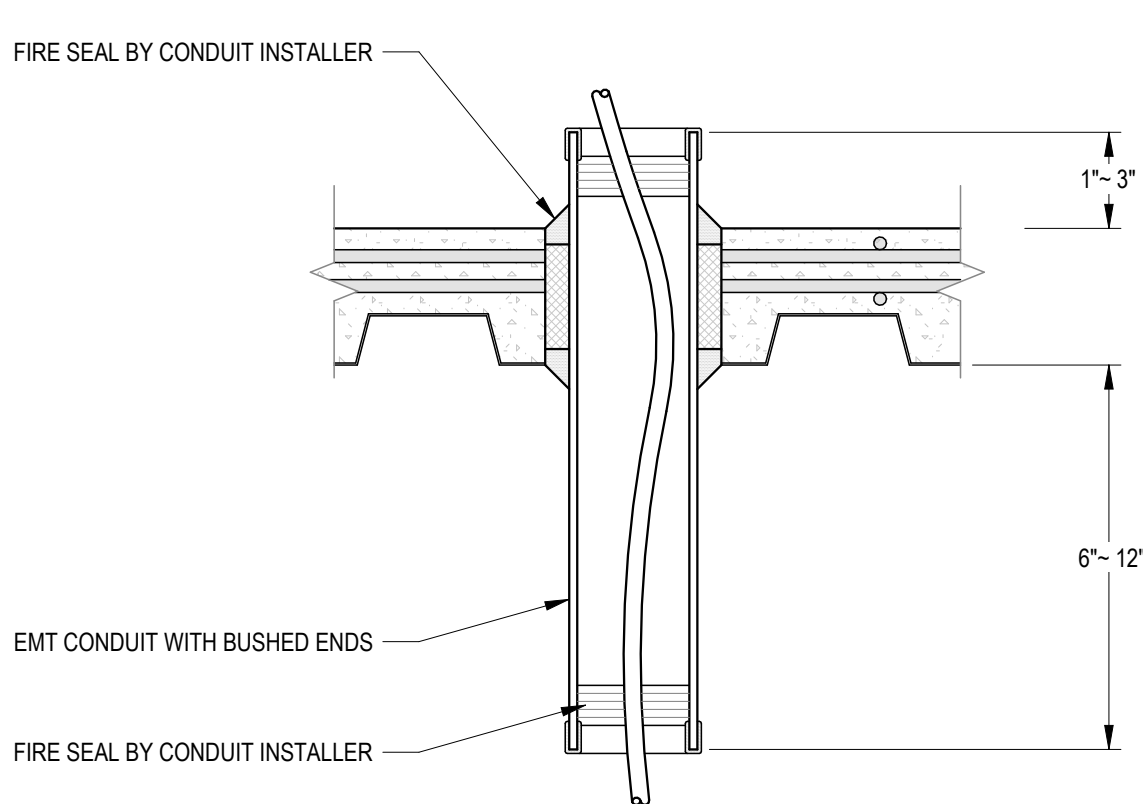

ITEM	QTY.	DESCRIPTION
1	4	CONCRETE ANCHOR, 1/2"

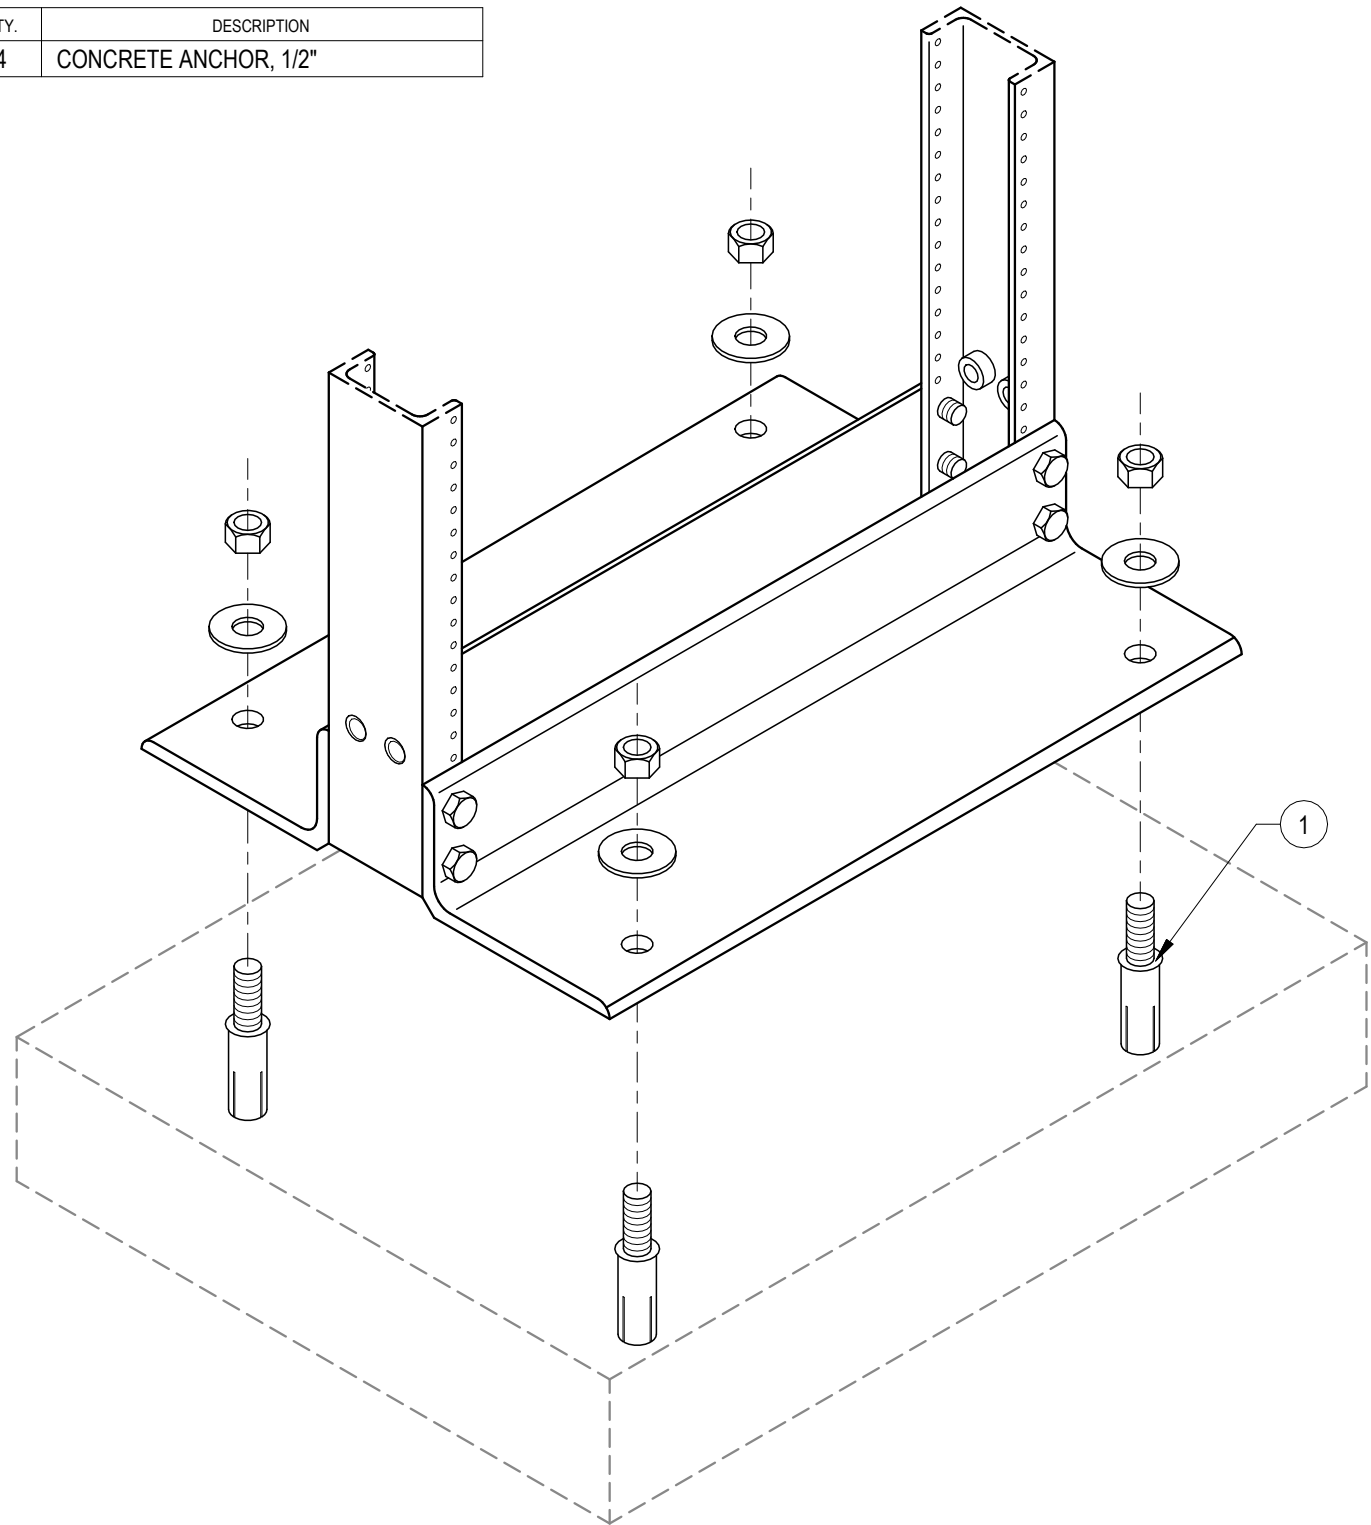


1	TELECOM FACEPLATES
T901	NTS

2	CONDUIT SLEEVE SECTION - THRU FLOOR SLAB
T901	NTS

3	CONDUIT SECTION - THRU FIRE RATED WALL
T901	NTS


5	FLOOR STANDING RACK MOUNT ASSEMBLY (2-POST)
T901	NTS

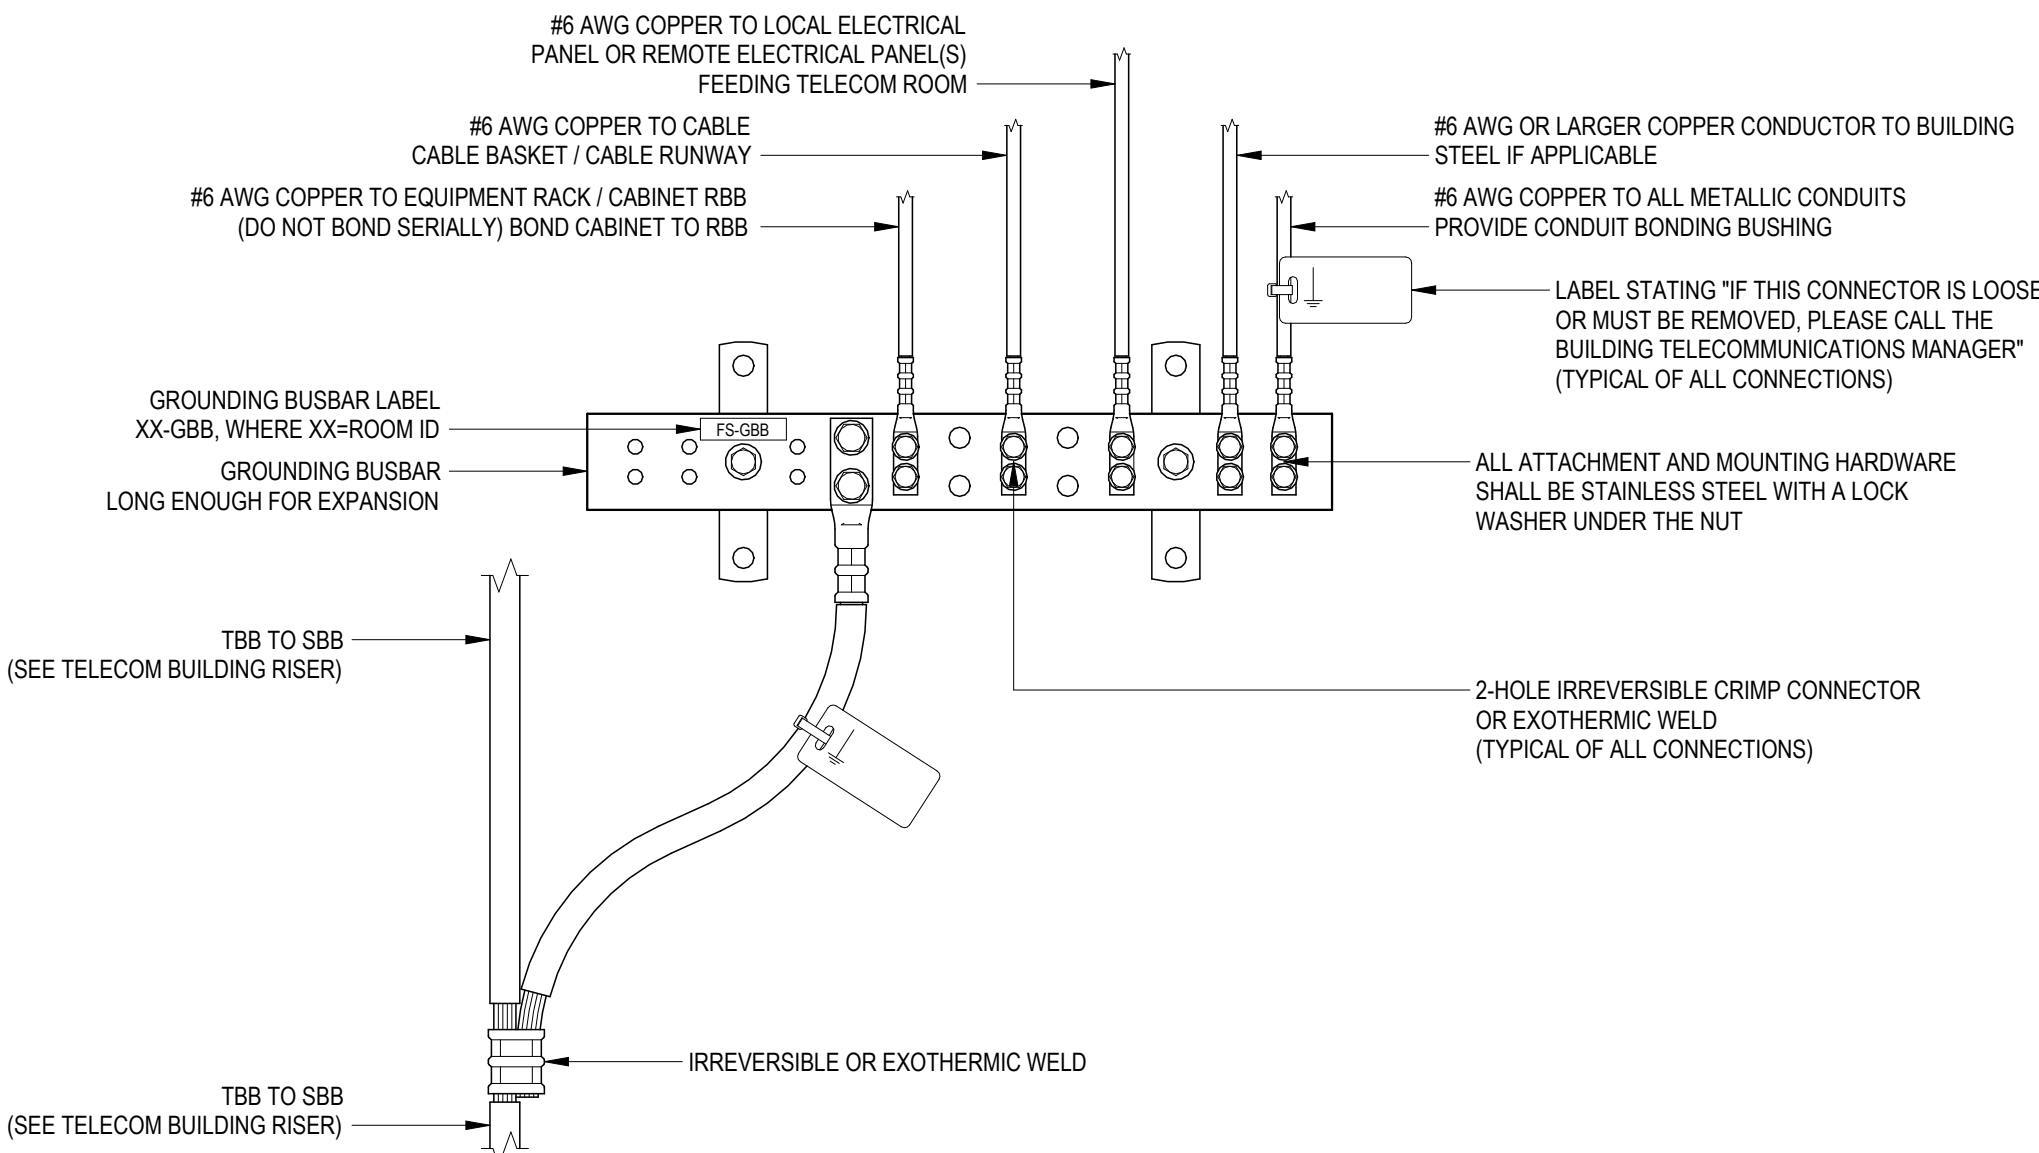


NOTES:

1. REFER TO ANSI/TIA-607-D FOR GROUNDING AND BONDING SPECIFICATIONS.
2. ALL BONDING CONDUCTORS SHALL BE IRREVERSIBLE CRIMP OR EXOTHERMIC WELD WHERE ACCESSIBLE, AND EXOTHERMIC WELD ONLY WHERE INSPECTION IS IMPRACTICAL.
3. REFER TO THE TELECOM BUILDING RISER FOR TBB AND BBC SIZES.
4. WHERE INSULATED, BONDING CONDUCTORS SHALL BE GREEN, GREEN WITH A YELLOW STRIPE OR MARKED WITH A DISTINCTIVE GREEN COLOR.
5. DO NOT SPLICE THE TBB OR BBC UNLESS NECESSARY, AND THE BUSBAR SHALL NOT BE USED TO JOIN SECTIONS OF THE TBB.
6. BUSBAR CONNECTIONS SHALL BE CLEANED AND ANTIOXIDANT GREASE SHOULD BE APPLIED PRIOR TO MATING SURFACES PRIOR TO FASTENING CONNECTORS TO THE BUSBAR.
7. THE INSIDE BEND RADIUS OF ALL BONDING CONDUCTORS ATTACHED TO THE PBB SHALL HAVE AN INSIDE BEND RADIUS OF 8 IN, 200 MM. AT OTHER LOCATIONS, BENDS IN THE BONDING CONDUCTORS SHOULD BE LIMITED TO THE GREATEST PRACTICAL INSIDE BEND RADIUS WITH A MINIMUM BEND RADIUS OF 10 TIMES THE BONDING CONDUCTOR DIAMETER RECOMMENDED. IN ALL CASES, THE MINIMUM BEND RADIUS ANGLE SHALL BE 90° OR GREATER.
8. MAINTAIN A MINIMUM OF 2" OF SEPARATION FROM ALL ELECTRICAL CONDUCTORS.

4	GROUNDING BUSBAR
T901	NTS

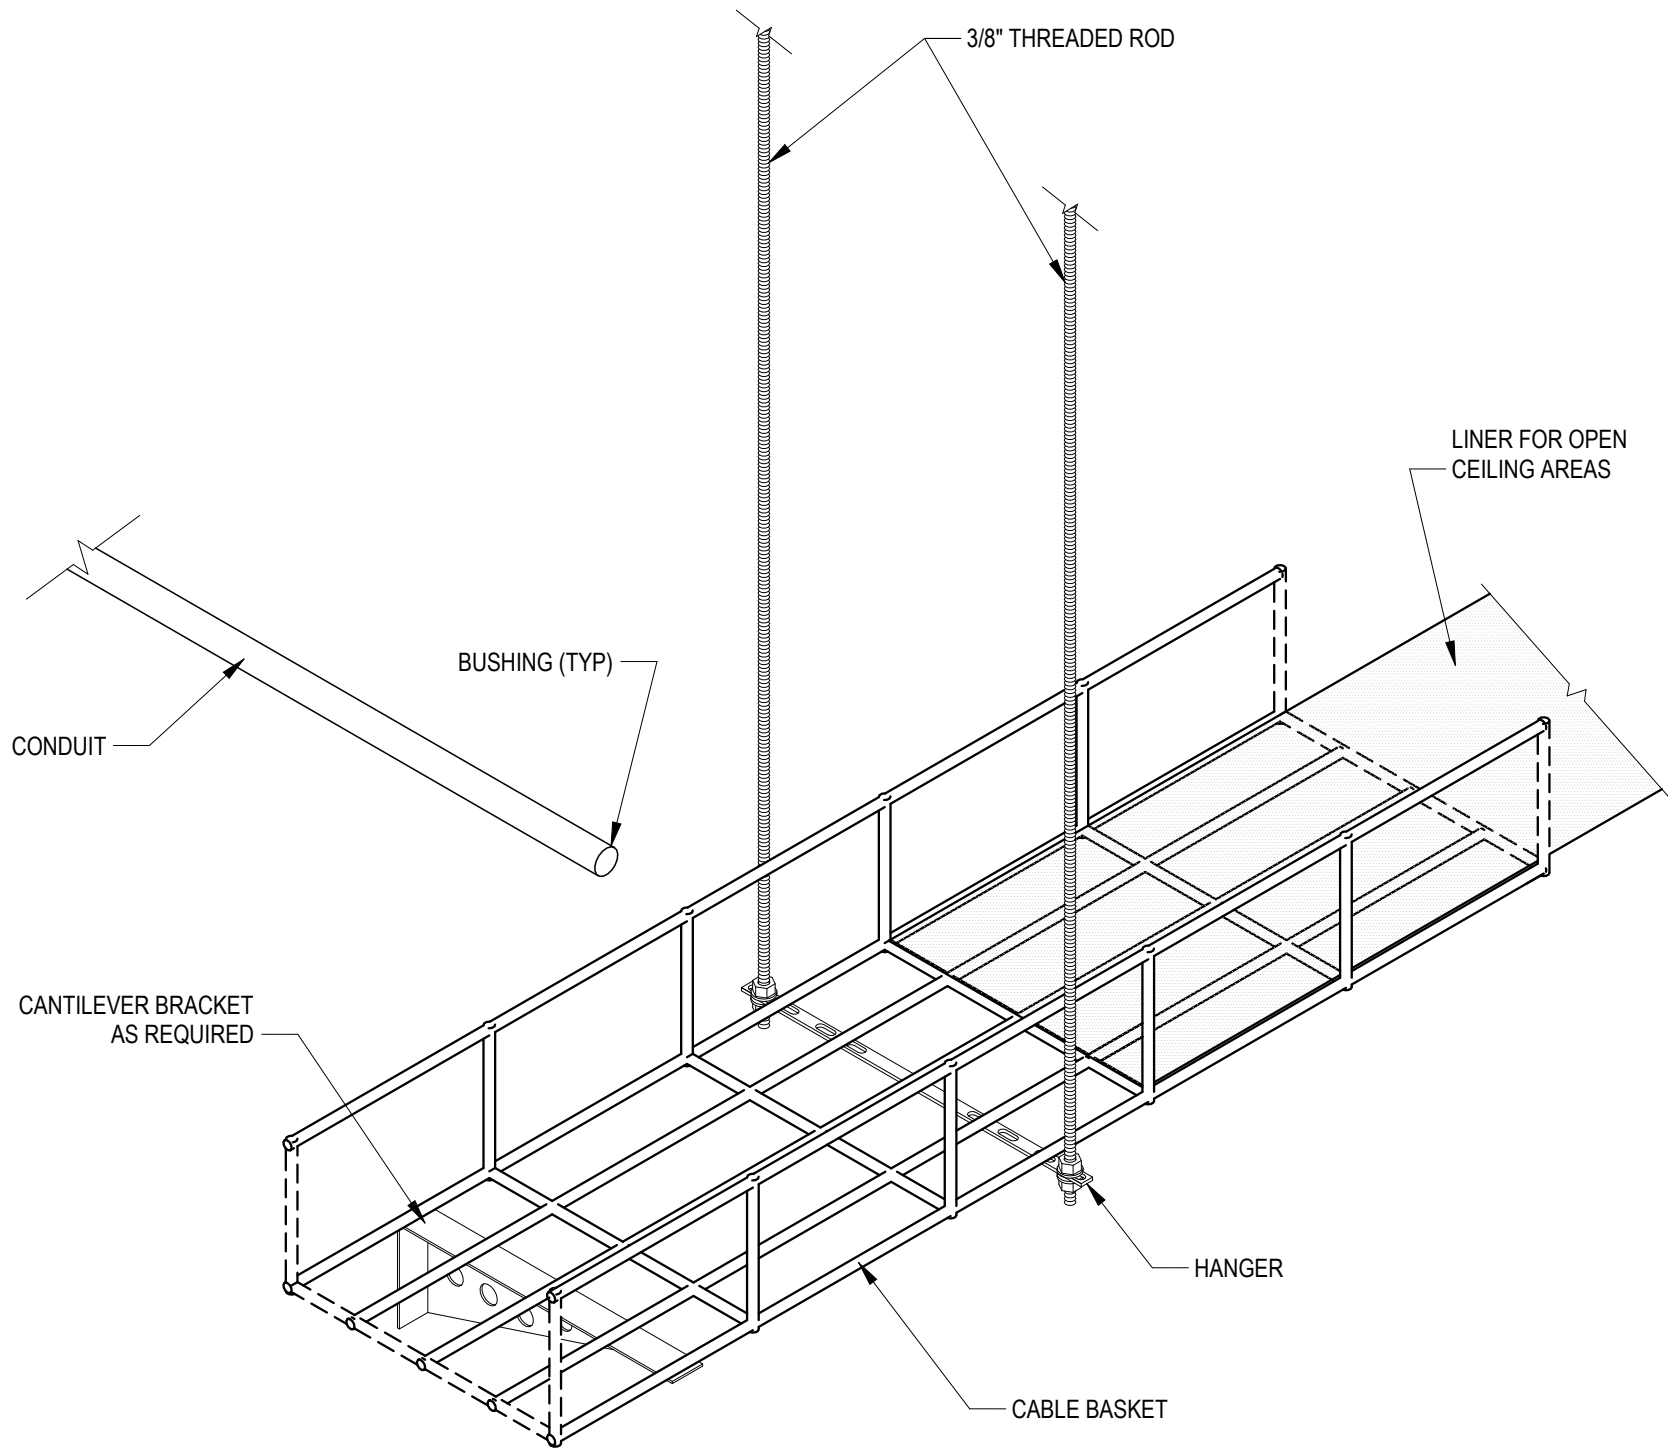

6	SUPPORT - SINGLE CABLE BASKET
T901	NTS

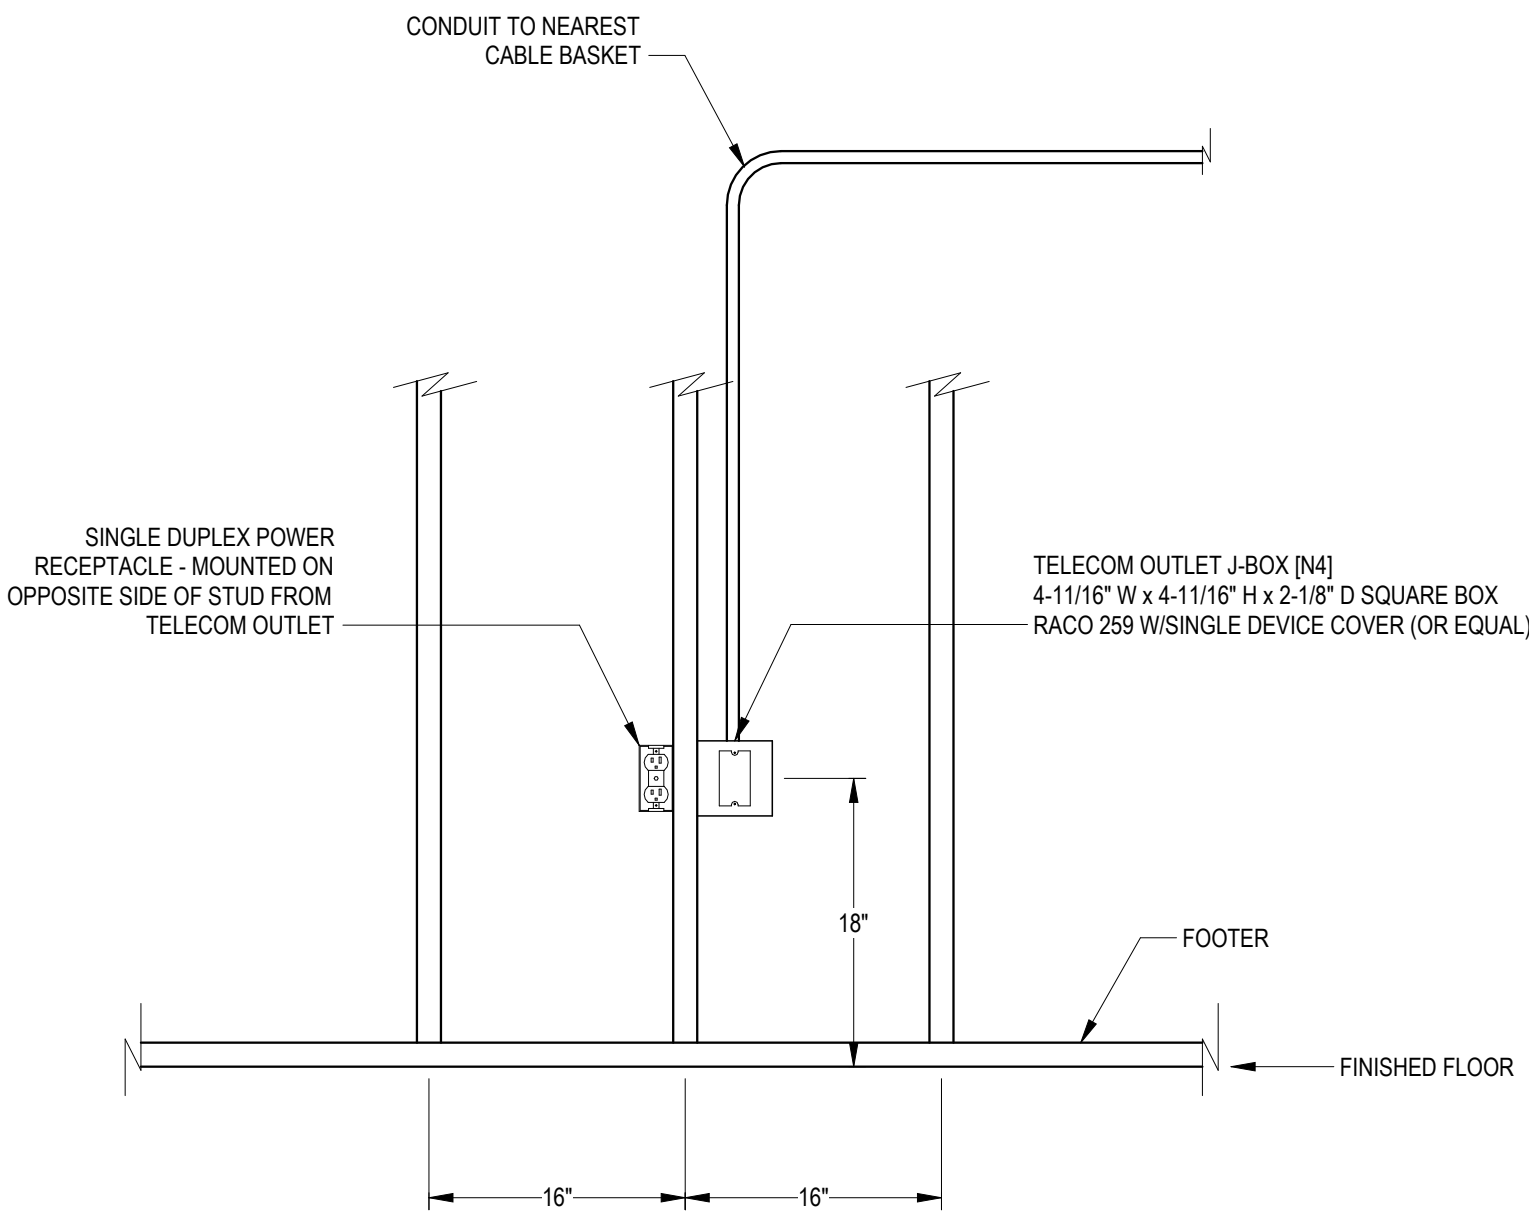

NOTES:

1. LOCATE POWER RECEPTACLE ON SIDE OF STUD CLOSEST TO ROOM ENTRANCE.
2. POWER RECEPTACLE TO BE LOCATED WITHIN 36" OF THE TELECOM WALL OUTLET.
3. SEE THE "TELECOM TYPICAL CONDUIT RISER" 1/7602 FOR CONDUIT REQUIREMENTS BY TELECOM JUNCTION BOX TYPE.

7	TELECOM OUTLET LOCATION WITH SINGLE DUPLEX POWER RECEPTACLE
T901	NTS

Van Buren Charter Township

Van Buren Township, MI

The Lakeside Park

REVISIONS

10/12/2026 BID AND PERMIT SET

Drawn By TGAUNTNER
Designer JFISHMAN, TROBINETTE
Reviewer DCHITTY, KKERSTETTER
Manager CKRETOVIC

Hard copy is intended to be 24"x36" when plotted. Scale(s) indicated and graphic quality may not be accurate for any other size.

PROJECT NO.

2500281

SHEET NO.

T901

©Copyright 2026
All Rights Reserved